


BID SET
APRIL 13, 2020

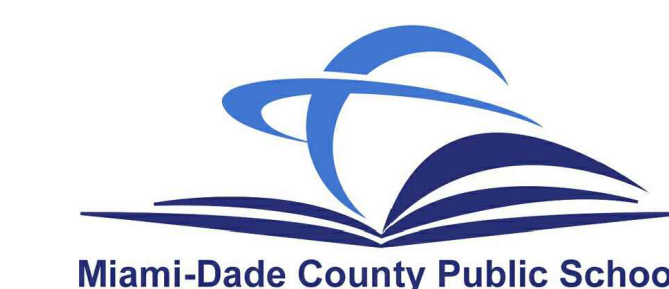

NEW ELEMENTARY SCHOOL (K-5) AT:
VENETIAN PARC WEST
S.W. 157th AVE & 174th STREET , MIAMI, FL 33187

NEW K-5 BUILDING
FACILITY AT:

**VENETIAN
PARC WEST
VOLUME I**

CONSULTANTS:

M/E/P ENGINEER:



LOUIS J. AGUIRRE & ASSOCIATES, P.A.
9150 Dadeland Blvd., Suite 900
Miami, FL 33156
TEL: (305) 670-0141
FAX: (305) 670-0144

STRUCTURAL ENGINEER:



DONNELL, DUQUESNE & ALBAISA, P.A.
4950 SW 74 COURT
Miami, FL 33155
TEL: (305) 666-0711
FAX: (305) 666-5259

CIVIL ENGINEER:



AVINO & ASSOCIATES, INC.
1850 S.W. 57th Avenue, Suite 207
West Miami, FL 33144
TEL: (305) 265-5030
FAX: (305) 265-5033

LANDSCAPE ARCHITECT:



LAURA LLERENA & ASSOCIATES, INC.
13170 S.W. 128th Street, Suite 207
Miami, FL 33186
TEL: (305) 256-1199
FAX: (305) 256-1155

**THE SCHOOL BOARD OF
MIAMI DADE COUNTY FLORIDA**

MS. PERLA TABARES HANTMAN, CHAIRPERSON
DR. MARTIN KARP, VICE-CHAIRPERSON

MS. SUSIE V. CASTILLO

DR. LAWRENCE S. FELDMAN

DR. MARTA PEREZ


DR. STEVE GALLON III

MS. LUBBY NAVARRO

DR. DOROTHY BENDROSS-MINDINGALL

MS. MARI TERE ROJAS

ALBERTO CARVALHO, SUPERINTENDENT OF SCHOOLS

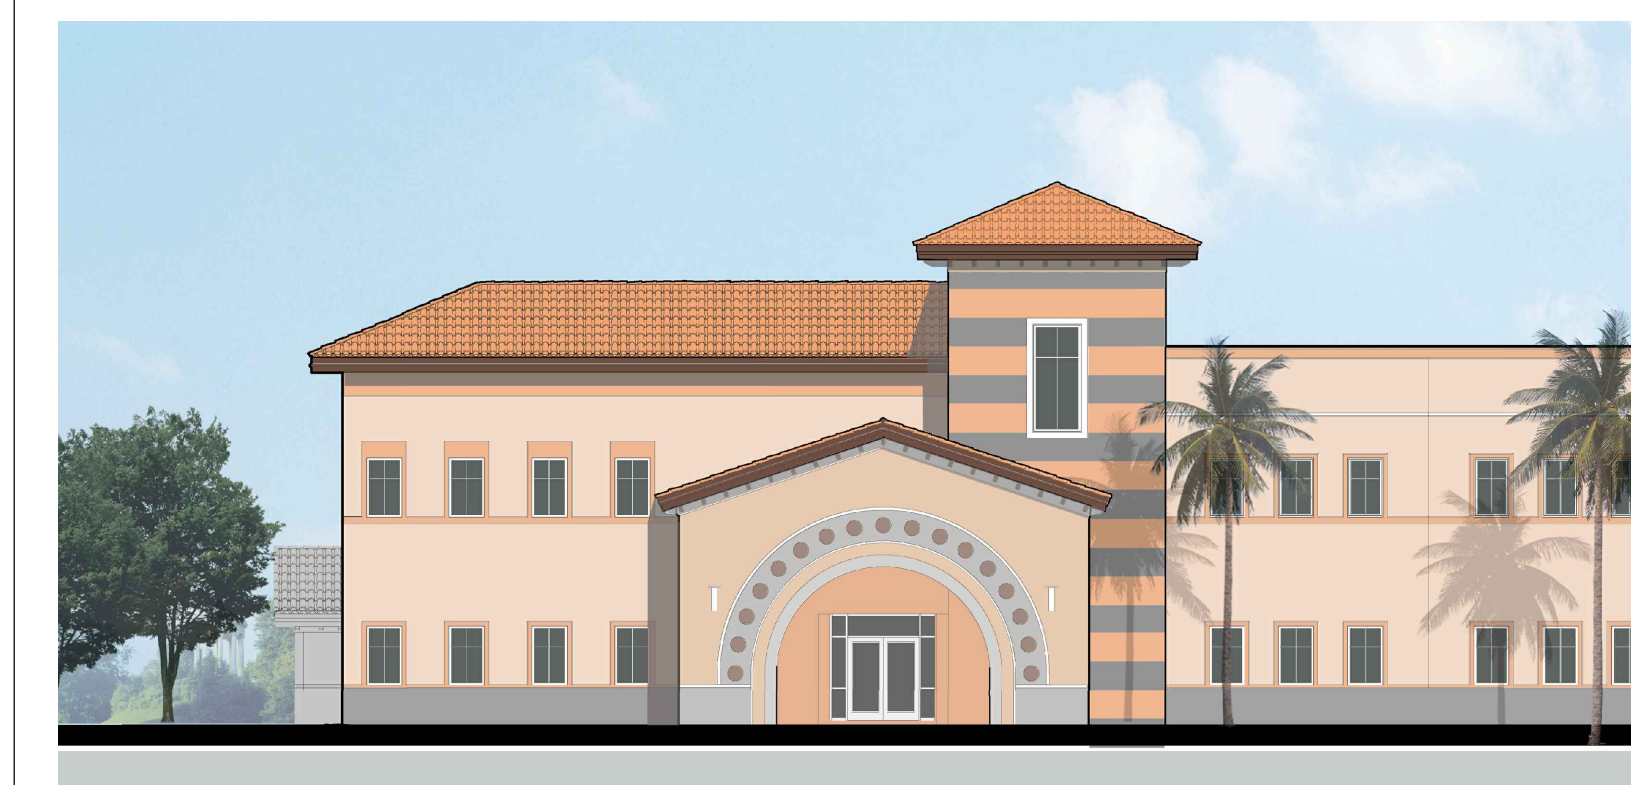

MDCPS PROJECT NO.
01892600

BID SET
APRIL 13, 2020

DRAWING INDEX

CIVIL, LANDSCAPE, ARCHITECTURAL, FOOD SERVICE AND STRUCTURAL

VOLUME I

INDEX OF DRAWINGS:									
SHEET COUNT	DWG. #	DESCRIPTION	REV. #1	REV. #2	REV. #3	REV. #4	REV. #5	REV. #6	REV. #7
VOLUME I									
1	GN-000	COVER SHEET - VOLUME I	X						
2	GN-100A	DRAWING INDEX - VOLUME I							
3	GN-101	GENERAL NOTES, ABBREVIATIONS, LOCATION MAP, SCOPE OF WORK, STATEMENT OF COMPLIANCE	X						
CIVIL									
4	C-1	COVER SHEET	X						
5	C-2	SITE GEOMETRY PLAN	X						
6	C-3	PAVING, GRADING AND DRAINAGE PLAN							
7	C-4	PAVEMENT MARKINGS AND SIGNAGE PLAN	X						
8	C-5	PAVING AND DRAINAGE DETAILS							
9	C-6	PAVING AND DRAINAGE DETAILS	X						
10	C-7	STORM WATER POLLUTION PREVENTION PLAN	X						
11	MS-1	WATER AND SEWER COVER SHEET							
12	MS-2	WATER AND SEWER PLAN	X						
13	MS-3	WATER AND SEWER PROFILE							
SURVEY									
14	SU-1	BOUNDARY SURVEY AND NOTES							
15	SU-2	PARTIAL TOPOGRAPHIC SURVEY							
IRRIGATION									
16	IR-100	IRRIGATION PLAN							
17	IR-101	IRRIGATION NOTES AND DETAILS							
LANDSCAPE									
18	L-100	LANDSCAPE PLAN							
19	L-101	LANDSCAPE NOTES AND DETAILS							
LIFE SAFETY									
20	LS-100	LIFE SAFETY - SITE PLAN	X						
21	LS-200	OVERALL FIRST & SECOND FLOOR - LIFE SAFETY	X						
22	LS-211	ENLARGED FIRST FLOOR, LIFE SAFETY PLAN - AREA A	X						
23	LS-212	ENLARGED FIRST FLOOR, LIFE SAFETY PLAN - AREA B	X						
24	LS-221	ENLARGED SECOND FLOOR, LIFE SAFETY PLAN - AREA A	X						
25	LS-222	ENLARGED SECOND FLOOR, LIFE SAFETY PLAN - AREA B	X						
ARCHITECTURE									
26	A-100	SITE PLAN	X						
27	A-101	ENLARGED SITE PLAN - PARKING AREA	X						
28	A-102	ENLARGED SITE PLAN - SERVICE YARD & PLAYCOURTS							
29	A-103	ENLARGED SITE PLAN - ENTRY PLAZA							
30	A-110	SITE PLAN DETAILS							
31	A-111	SITE DETAILS	X						
32	A-112	SITE PLAN DETAILS	X						
33	A-113	MISC. SITE COURT DETAILS							
34	A-200	OVERALL 1ST & 2ND FLOOR PLANS							
35	A-211	ENLARGED 1ST FLOOR PLAN - AREA A	X						
36	A-212	ENLARGED 1ST FLOOR PLAN - AREA B	X						
37	A-221	ENLARGED 2ND FLOOR PLAN - AREA A							
38	A-222	ENLARGED 2ND FLOOR PLAN - AREA B							
39	A-240	MISCELLANEOUS TILT PANELS DETAILS	X						
40	A-241	MISCELLANEOUS TILT PANELS DETAILS	X						
41	A-311	1ST FLOOR REFLECTED CEILING PLAN - AREA A	X						
42	A-312	1ST FLOOR REFLECTED CEILING PLAN - AREA B	X						
43	A-321	2ND FLOOR REFLECTED CEILING PLAN - AREA A	X						
44	A-322	2ND FLOOR REFLECTED CEILING PLAN - AREA B	X						
45	A-330	CEILING DETAILS							
46	A-401	OVERALL ROOF PLAN							
47	A-420	ROOF DETAILS							
48	A-421	ROOF DETAILS							
49	A-422	ROOF DETAILS	X						
50	A-501	EXTERIOR BUILDING ELEVATIONS							
51	A-502	EXTERIOR BUILDING ELEVATIONS							
52	A-503	EXTERIOR BUILDING ELEVATIONS							
53	A-601	OVERALL BUILDING SECTIONS	X						
54	A-602	OVERALL BUILDING SECTIONS	X						
55	A-603	BUILDING SECTIONS	X						
56	A-604	BUILDING SECTIONS							
57	A-605	BUILDING SECTIONS	X						
58	A-606	BUILDING SECTIONS	X						
59	A-621	BUILDING WALL SECTIONS	X						
60	A-622	BUILDING WALL SECTIONS / DETAILS							
61	A-630	ENLARGED STAIRS #1 PLANS & SECTION							
62	A-631	ENLARGED STAIRS #2 PLANS & SECTION							
63	A-632	ENLARGED STAIRS #3 PLANS & SECTION							
64	A-633	ENLARGED ELEVATOR PLANS, SECTION & DETAILS							
65	A-640	RAILING & STAIR DETAILS							
66	A-650	WALL TYPES	X						
67	A-660	FIRESTOP PENETRATION/JOINT SCHEDULE	X						
68	A-681	FIRESTOPPING PENETRATION DETAILS							
69	A-682	FIRESTOPPING PENETRATION DETAILS							
70	A-700	TYPICAL MOUNTING HEIGHTS & NOTES							
71	A-701	OVERALL 1ST & 2ND FLOOR FURNITURE PLANS							
72	A-702	ENLARGED 1ST FLOOR ADMINISTRATION - BUILDING 1A							
73	A-703	ENLARGED ADMINISTRATION INTERIOR ELEVATIONS							
74	A-704	ENLARGED 1ST FLOOR MEDIA CENTER & INTERIOR ELEVATIONS - BUILDING 1A							
75	A-705	ENLARGED 1ST FLOOR MUSIC/ DINING & INTERIOR ELEVATIONS - BUILDING 1A							
76	A-706	ENLARGED DINING/ MULTIPURPOSE ROOM INTERIOR ELEVATIONS							
77	A-707	ENLARGED 1ST FLOOR ART LAB, PRIMARY CLASSROOM & INTERIOR ELEVATIONS							
78	A-708	ENLARGED KINDERGARTEN CLASSROOM & INTERIOR ELEVATIONS							
79	A-709	ENLARGED PRIMARY & INTERMEDIATE CLASSROOM & INTERIOR ELEVATIONS							
80	A-710	ENLARGED RESOURCE ROOM & TEACHER PLANNING & INTERIOR ELEVATIONS							
81	A-711	ENLARGED EXTENDED LEARN PLAN & INTERIOR ELEVATIONS - GROUND LEVEL							
82	A-712	ENLARGED TOILET PLANS & ELEVATIONS	X						
83	A-713	ENLARGED TOILET PLANS & ELEVATIONS							
84	A-714	ENLARGED TOILET PLANS & ELEVATIONS	X						
85	A-715	ENLARGED EXTENDED LEARN PLAN & ELEVATIONS							
86	A-750	CASEWORK DETAILS							
87	A-751	RECEPTION DESK DETAILS							
88	A-752	MEDIA DESK DETAILS							
89	A-800	DOOR, WINDOW & LOUVER TYPES							
90	A-810	DOOR SCHEDULE - FIRST FLOOR	X						
91	A-811	DOOR SCHEDULE - SECOND FLOOR							
92	A-820	DOOR HEAD & JAMB DETAILS							
93	A-821	DOOR THRESHOLD DETAILS							
94	A-830	WINDOW HEAD, JAMB & SILL DETAILS							

FINISH PLANS									
95	ID-100	SIGNAGE DETAILS							
96	ID-211	ENLARGED 1ST FLOOR FINISH & SIGNAGE PLAN - AREA A							
97	ID-212	ENLARGED 1ST FLOOR FINISH & SIGNAGE PLAN - AREA B							
98	ID-213	OVERALL 1ST FLOOR PATTERN							
99	ID-221	ENLARGED 2ND FLOOR FINISH & SIGNAGE PLAN - AREA A							
100	ID-222	ENLARGED 2ND FLOOR FINISH & SIGNAGE PLAN - AREA B							
101	ID-223	OVERALL 2ND FLOOR PATTERN							
FOOD SERVICE									
102	FS-1.1	FOOD SERVICE EQUIPMENT PLAN							
103	FS-1.2	FOOD SERVICE ELECTRICAL PLAN							
104	FS-1.3	FOOD SERVICE PLUMBING PLAN							
105	FS-1.4	FOOD SERVICE SPECIAL CONDITIONS							
106	FS-1.5	FOOD SERVICE EQUIPMENT DETAILS							
STRUCTURAL									
107	S-221	FOUNDATION & GROUND FLOOR PLAN, AREA A							
108	S-222	FOUNDATION & GROUND FLOOR PLAN, AREA B							
109	S-223	SECOND FLOOR FRAMING PLAN, AREA A							
110	S-224	SECOND FLOOR FRAMING PLAN, AREA B							
111	S-225	ROOF FRAMING PLAN, AREA A							
112	S-226	ROOF FRAMING PLAN, AREA B							
113	S-300	GENERAL STRUCTURAL NOTES	X						
114	S-301	SCHEDULES AND DETAILS	X						
115	S-302	TYPICAL DETAILS							
116	S-303	BEAM SCHEDULES AND DETAILS							
117	S-401	SECTIONS							
118	S-402	SECTIONS							
119	S-403	SECTIONS							
120	S-404	SECTIONS							
121	S-405	SECTIONS							
122	S-406	SECTIONS							
123	S-407	SECTIONS							
124	S-408	SECTIONS							

CHECKED BY:
LR


DRAWN BY:
C.V.

CONSULTANT INFO:



NEW ELEMENTARY SCHOOL (K-5)
VENETIAN PARC WEST
SOUTHWEST 157th AVENUE and 174th STREET
MIAMI, FL. 33187
MDCPS PROJECT No. 01892600


KEY PLAN

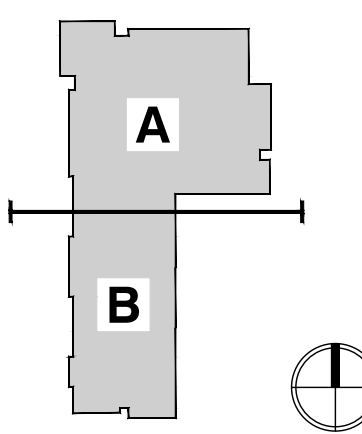

CONSULTANT INFO:

DESIGN & RODRIGUEZ PARR
FLORIDA REGISTERED PROFESSIONAL ARCHITECTS
FLORIDA REGISTRATION NO. 11999

**RODRIGUEZ
ARCHITECTS
INCORPORATED**
2121 PONCE DE LEON BLVD. STE. 1010
CORAL GABLES, FL. 33134
TEL: (305) 448-3373
FAX: (305) 448-3374
A A C — 0 0 1 9 3 3

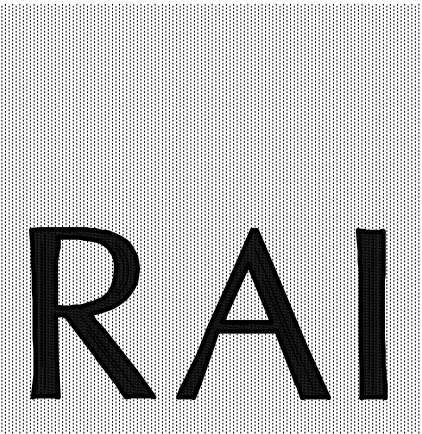

REVISIONS:

02/14/2020	BUILDING DEPARTMENT COMMENTS

DRAWING TITLE:

DRAWING INDEX VOLUME I	
SCALE AS NOTED	
ISSUE DATE: 12/16/19	PROJECT NO: 1906
SHEET: GN-100A	

ABBREVIATIONS

ABV.	ABOVE	INSUL.	INSULATION
A.C.	AIR CONDITIONING	INT.	INTERIOR
ACOUS.	ACOUSTICAL	INV.	INVERT
A.C.T.	ACOUSTICAL CEILING TILE	JOINT	JOINT
ADMIN.	ADMINISTRATION	KIT.	KITCHEN
AREA	AREA DRAIN	LAV.	LAVATORY
ADJ.	ADJACENT / ADJUSTABLE	L.F.	LINEAR FEET
A.F.F.	ABOVE FINISH FLOOR	L.P.	LOW POINT
APP.	ACOUSTICAL FINISH PLASTER	MAX.	MAXIMUM
A.H.U.	AIR HANDLING UNIT	MECH.	MECHANICAL
ALUM.	ALUMINUM	MFR.	MANUFACTURER
ANOD.	ANODIZED	MGR.	MANAGER
ARCH.	ARCHITECTURAL	MH.	MANHOLE
A.S.B.	ASBESTOS	MIN.	MINIMUM
ASPH.	ASPHALT	MISC.	MISCELLANEOUS
ASST.	ASSISTANT	M.O.	MASONRY OPENING
BATT.	BATT INSULATION	METAL	METAL
BB.	BACKER BOARD	NA	NOT APPLICABLE
BOARD	BOARD	NC	NON-COMBUSTIBLE
BLDG.	BUILDING	N.I.C.	NOT IN CONTRACT
BLK.	BLOCK / BLOCKING	No. / NUM.	NUMBER
BM.	BEAM	NOM.	NOMINAL
B.O.	BOTTOM OF	N.T.S.	NOT TO SCALE
CAB.	CABINET	O.C.	ON CENTER
CB	CATCH BASIN	O.D.	OUTSIDE DIAMETER
CEM.	CEMENT	O.F.I.C.	OWNER FURNISHED, CONTRACTOR INSTALLED
C.PLAS.	CEMENT PLASTER	OFF.	OFFICE
C.G.	CORNER GUARD	OPNG.	OPENING
C.HGT.	CEILING HEIGHT	P.L.	PROPERTY LINE
C.JNT.	CONTROL JOINT	P.LAM.	PLASTIC LAMINATE
CLR.	CLEAR (FINISH TO FINISH)	PLAS.	PLASTER
COLM.	COLUMN	PLUMB.	PLUMBING
COMP.	COMPUTER	PLYWD.	PLYWOOD
CPT.	CARPET	P.O.B.	POINT OF BEGINNING
CT.	CERAMIC TILE	PR.	PAIR
CLG.	CEILING	PTD.	PAINTED
C.O.	CLOSET	R	RISER
CLM.	COLUMN	RAD.	RADIUS
CONC.	CONCRETE	R.D.	ROOF DRAIN
CONT.	CONTINUOUS	REF.	REFERENCE
C.M.U.	CONCRETE MASONRY UNIT	REFL.	REFLECTED
DETL.	DETAIL	REINF.	REINFORCED
DIA.	DIAMETER	REQ.	REQUIRED
DIR.	DIRECTOR	RM.	ROOM
DN.	DOWN	R.O.	ROUGH OPENING
D.O.	DOOR OPENING	RT	RESILIENT TILE
DR.	DOOR	SC	SOLID CORE
DWR.	DRAWER	SCHD.	SCHEDULE
DWG.	DRAWING	SERV.	SERVICE
EA.	EACH	SHR.	SHOWER
ELEC.	ELECTRICAL	SHT.	SHEET
ELEV.	ELEVATION	SIM.	SIMILAR
EL	ELEVATOR	SPECS.	SPECIFICATIONS
E.N.C.	EXISTING, NO CHANGE	SO.	SQUARE
E.O.S.	EDGE OF SLAB	SL	SLOPE
EQ.	EQUAL	SLD.	SLIDING
EQUIP.	EQUIPMENT	SREF	STATE REQUIREMENTS FOR EDUCATIONAL FACILITIES (2014 ED.)
E.W.C.	ELECTRIC WATER COOLER	S.S.	SERVICE SINK
EXH.	EXHAUST	S.STL.	STAINLESS STEEL
EXIST.	EXISTING	STL	STEEL
EXT.	EXTERIOR	STOR.	STORAGE
EXP.JT.	EXPANSION JOINT	STRUCT.	STRUCTURAL
FBC 2017	FLORIDA BUILDING CODE (2017)	SUSP.	SUSPENDED
F.D.	FIRE DAMPER	SYM.	SYMMETRICAL
F.F.E.	FINISH FLOOR ELEVATION	TEL	TELEPHONE
F.F.@ E.	FIXTURES, FURNITURE, AND EQUIPMENT	TEMP	TEMPERED
F.F.P.C.	FLORIDA FIRE PROTECTION CODE	THK.	THICKNESS
FIXT.	FIXTURE	T.O.	TOP OF
FLASH.	FLASHING	TYP.	TYPICAL
FLD.	FLOOR DRAIN	UA	UNLIMITED AREA
F.O.F.	FACE OF FINISH	U.C.	UNDER COUNTER
F.R.	FIRE RATED	U.L.	UNDERWRITERS LABORATORY
GA.	GAUGE	U.O.N.	UNLESS OTHERWISE NOTED
GALV.	GALVANIZED	VERT.	VERTICAL
GEN.	GENERATOR	VEST.	VESTIBULE
GL.	GLASS	VERT.	VERIFY IN FIELD
G.W.B.	GYPSUM WALL BOARD	V.I.F.	VINYL WALL COVERING
H/C	HANDICAP	VVC	VINYL WALL COVERING
HC	HOLLOW CORE	VT	VINYL TILE
HDWD.	HARDWOOD	W	WITH
HM	HOLLOW METAL	W.C.	WATER CLOSET
HORIZ.	HORIZONTAL	WD	WOOD
HGT.	HEIGHT	W/O	WITHOUT
H.P.	HIGH POINT	WP.	WATERPROOF
I.DIA.	INSIDE DIAMETER	WT.	WEIGHT

LEGEND OF MATERIALS

	TILT-UP CONCRETE PANELS INDICATED ON PLANS ONLY
	CONCRETE MASONRY
	CONCRETE IN SECTION
	DRYWALL / STUD PARTITION
	RIGID INSULATION INDICATED IN ENLARGED DETAILS / SECTIONS
	EARTH
	GRAVEL / POROUS FILL
	BATT INSULATION
	PLYWOOD
	FINISHED PLYWOOD
	WOOD BLOCKING
	WOOD
	METAL LATH

SYMBOLS

	PROPERTY LINE
	DATUM - NATIONAL GEODETIC VERTICAL DATUM (EX. 0'-0"A.F.F.= X'-X" N.G.V.D.)
	SECTION NUMBER
	SHEET NUMBER
	WALL SECTION
	EXTERIOR ELEVATION
	COLUMN GRID
	REVISION TYPE
	DATE
	WINDOW TYPE
	LOUVER TYPE
	DOOR NUMBER
	PARTITION TYPE
	ROOM NAME
	ROOM NUMBER
	SF PROVIDED / SF REQUIRED
	STUDENT STATIONS
	FISH ROOM NAME
	FISH ROOM NUMBER
	FISH SF
	FISH STUDENT STATIONS
	SLAB DEPRESSION
	INTERIOR ELEVATION
	CARD READER

LIFE SAFETY SYMBOLS

	AGGREGATE LENGTH
	FARTHEST POINT - EXIT DISTANCE
	TRAVEL DISTANCE (ONLY FARTHEST CONDITION SHOWN FOR CLARITY)
	4-HOUR WALL SEPARATION RATING
	3-HOUR WALL SEPARATION RATING
	2-HOUR WALL SEPARATION RATING
	1-HOUR WALL SEPARATION RATING
	1-HR FIRE SMOKE BARRIER
	SMOKE RATED PARTITION SEPARATION
	EXIT PATH
	EMERGENCY LIGHT - WALL MOUNTED
	ILLUMINATED EXIT LIGHT (DIRECTION OF TRAVEL)
	FIRE ALARM HORN AND STROBE
	FIRE ALARM HORN ONLY
	FIRE ALARM PULL STATION
	FIRE ALARM STROBE ONLY
	FIRE ALARM PANEL
	CLOCK-SPEAKER SYSTEM
	ANSUL SYSTEM
	STANDPIPE, HOSE CABINET, CHARGED
	STANDPIPE, DRY HOSE STATION
	MAGNETIC DOOR HOLDER
	HEAT DETECTOR
	SMOKE DETECTOR
	FIRE BLANKET W/ FIRE EXT.
	FIRE BLANKET
	EMERGENCY-SHOWER/EYE WASH
	EYE WASH/SHOWER
	FIRE EXTINGUISHER - WALL MOUNTED
	FIRE EXTINGUISHER CABINET SEMI-RECESSED
	EMERGENCY 2X4 LIGHT
	EMERGENCY STRIP LIGHT
	FIRE SIAMESE CONNECTION (WALL OR HYDRANT)
	HOSE CABINET W/FEX
	EMERGENCY DISCONNECT
	1- NUMBER OF OCCUPANTS LEAVING
	2- REQUIRED WIDTH (inches)
	3- PROVIDED WIDTH (inches)
	ROOM OCCUPANCY

CEILING SYMBOLS


	2X4 FLUORESCENT LIGHT FIXTURE
	1X4 FLUORESCENT LIGHT FIXTURE
	FLUORESCENT STRIP LIGHT FIXTURE
	FLUORESCENT STRIP LIGHT FIXTURE - WALL MOUNTED
	RECESSED HIGH-HAT LIGHT FIXTURE
	PENDANT LIGHT FIXTURE
	2' x 4' SURFACE MOUNTED LIGHT FIXTURE
	1' x 4' SURFACE MOUNTED LIGHT FIXTURE
	1' x 4' SURFACE MOUNTED LIGHT FIXTURE
	WALL MOUNTED LIGHT FIXTURE
	CEILING MOUNTED LIGHT FIXTURE
	CEILING MOUNTED WALL WASHER
	A/C SUPPLY GRILL
	EXIT SIGN - CEILING MOUNTED
	EXIT SIGN - SURFACE MOUNTED
	A/C SUPPLY GRILL (SEE MECHANICAL DRAWINGS FOR SIZE, OUTPUT ETC.)
	A/C AIR RETURN GRILL (SEE MECHANICAL DRAWINGS FOR SIZE, OUTPUT ETC.)
	2' x 4' PYRAMIDAL ACOUSTIC DIFFUSER PANELS
	2X4 EMERGENCY LIGHT FIXTURE (SHADE INDICATES EMERGENCY)
	INCANDESCENT OR H.I.D. FIXTURE (SEE REFL. LT. FINISH SCH.)
	EMERGENCY LIGHT FIXTURE
	EXHAUST FAN
	LINEAR DIFFUSER
	2X4 ACOUSTICAL LAY-IN CEILING
	2X2 ACOUSTICAL LAY-IN CEILING
	GYPSUM DRYWALL CEILING OR SOFFIT AREA
	CEMENT PLASTER ON GYP, DRYWALL
	STUCCO CEMENT PLASTERED ON METAL LATH SUSPENDED SYSTEM

GENERAL NOTES

- CONTRACTOR SHALL COMPLY WITH THE 2017 FLORIDA BUILDING CODE w/ APPLICABLE SUPPLEMENTS, THE 6TH ED. FLORIDA FIRE PREVENTION CODE, ALL STATE AND LOCAL ZONING CODES AND PERMITS SHALL BE POSTED IN A VISIBLE PLACE AT ALL TIMES. ALL PERMITS, UTILITY AND METER CONNECTION FEES SHALL BE OBTAINED AND PAID FOR BY THE CONTRACTOR.
- ALL WORK, MATERIALS AND EQUIPMENT UTILIZED IN THIS PROJECT SHALL BE NEW AND INSTALLED IN STRICT ACCORDANCE WITH THE MANUFACTURERS RECOMMENDATIONS AND SPECIFICATIONS.
- ALL WORK FOR THIS PROJECT SHALL CONFORM TO STANDARDS PUBLISHED BY RECOGNIZED PROFESSIONAL AND INDUSTRY ORGANIZATIONS.
- CONTRACTOR SHALL BE RESPONSIBLE FOR VISITING THE SITE PRIOR TO BIDDING AND FAMILIARIZING HIMSELF WITH ALL EXISTING CONDITIONS AFFECTING THE WORK, INCLUDING BUT NOT LIMITED TO PRIVATE AND PUBLIC UTILITIES, ON AND OFF SITE, ACCESS ROADS AND OTHER SUPPORT FACILITIES.
- CONTRACTOR TO REMOVE, RELOCATE OR RE-ROUTE, AS NECESSARY, ELECTRICAL, TELEPHONE, WATER, SEWER, GAS OR ANY OTHER UTILITY LINES ENCOUNTERED AND SHALL COORDINATE THIS WORK WITH ALL LOCAL UTILITY COMPANIES.
- NOT USED.
- CONTRACTOR SHALL IMMEDIATELY NOTIFY THE ARCHITECT OF ANY UNEXPECTED OR UNKNOWN FIELD CONDITIONS, ERRORS, OMISSIONS, OR DISCREPANCIES IN THE DRAWINGS, PROJECT MANUAL, OR CONTRACT DOCUMENTS PRIOR TO PROCEEDING WITH THE WORK OR SHOP FABRICATIONS.
- CONTRACTOR SHALL PREPARE AND MAINTAIN ALL CONSTRUCTION AREAS, AS WELL AS SURROUNDING AREAS FREE OF DEBRIS OR HAZARDOUS EQUIPMENT AT ALL TIMES.
- CONTRACTOR SHALL BE RESPONSIBLE FOR THE REPAIR AND/OR THE REPLACEMENT OF ANY ITEMS DAMAGED DURING CONSTRUCTION OR CLEAN-UP. CONSTRUCTION PERSONNEL SHALL BE CONFINED TO THE LIMITS OF THE CONSTRUCTION AREA. ALL OSHA REGULATIONS FOR CONSTRUCTION AREAS SHALL BE STRICTLY FOLLOWED.
- DRAWINGS ARE NOT TO BE SCALED. WRITTEN DIMENSIONS SHALL BE FOLLOWED.
- ALL DIMENSIONS ARE BASED ON NOMINAL SIZES OF MEMBERS AND ARE GIVEN TO THE OUTER FACE OF SUCH MEMBERS (UN), NOT TO FACE OF FINISH MATERIALS UNLESS OTHERWISE NOTED ON DRAWINGS. WHERE A DIMENSION IS LABELED "CLEAR" IT IS TAKEN FROM THE FACE OF FINISH MATERIALS TO FACE OF FINISH MATERIALS.
- CONTRACTOR TO SUBMIT SHOP DRAWINGS FOR APPROVAL BEFORE COMMENCING FABRICATION AND/OR INSTALLATION OF ALL APPLICABLE ITEMS FOR CONSTRUCTION. ALL SHOP DRAWINGS DIMENSIONS SHALL BE FIELD VERIFIED, REVIEWED AND APPROVED BY CONTRACTOR BEFORE SUBMITTAL. SHOP DRAWINGS WHICH ARE INCOMPLETE OR LACKING SUFFICIENT INFORMATION WILL BE RETURNED WITHOUT REVIEW. REFER TO SPECIFICATIONS FOR ADDITIONAL REQUIREMENTS.
- THE CONTRACTOR SHALL BE AWARE THAT SPECIFIC FIRE-RATED SEPARATION WITHIN THE BUILDING'S CONSTRUCTION ARE REQUIRED BY CODE. THE USE OF SPECIFIC MATERIALS AND COMBINATIONS OF MATERIALS WITHIN FIRE RATED ASSEMBLIES, AS CALLED FOR ON THE DRAWINGS AND SPECIFICATIONS, ARE FOR THE PURPOSE OF ACHIEVING THOSE REQUIRED FIRE SEPARATIONS. IT SHALL BE THE CONTRACTOR'S RESPONSIBILITY TO VERIFY THAT ANY CHANGE IN MATERIAL THAT IS REQUESTED BY OR MADE BY THE CONTRACTOR AND/OR ITS SUBCONTRACTORS, FROM THOSE MATERIALS DRAWN OR SPECIFIED, DOES NOT IN ANY WAY AFFECT OR LESSEN THE REQUIRED CONSTRUCTION ASSEMBLY. SPECIFIC SEQUENCES OR METHODS OF ACHIEVING FIRE RATED ASSEMBLIES REQUIRED BY A "U.L. No." LISTING SHALL BE FOLLOWED WITHOUT DEVIATION, UNLESS OTHERWISE NOTED OR DETAILED.
- WHERE CMU OR TILT-UP CONCRETE WALLS ARE INDICATED TO HAVE A SPECIFIC HOURLY FIRE RATING, THIS SHALL BE TAKEN AS THE MINIMUM ALLOWED.
- THE USE OF FIRE RETARDANT TREATED WOOD IS PROHIBITED. PRESSURE TREATED WOOD SHALL BE USED WHERE WOOD IS IN CONTACT WITH CONCRETE OR MASONRY OR IN CONTACT WITH THE ELEMENTS (EXTERIOR).
- CONTRACTOR TO FURNISH AND INSTALL ALL METAL AND WOOD BLOCKING REQUIRED FOR WALL MOUNTED OR BRACED FIXTURES, MILLWORK, SHELVES, BATHROOM FIXTURES AND ACCESSORIES OR BY OTHER ITEMS DESCRIBED IN INTERIOR DESIGN AND ARCHITECTURAL DRAWINGS.
- IN ADDITION TO WALL TYPES SHOWN ON PLANS THE CONTRACTOR SHALL REFER TO THE ROOM FINISH SCHEDULE, INTERIOR ELEVATIONS AND DETAILS FOR ADDITIONAL INFORMATION REGARDING FINISHES.
- CONTRACTOR SHALL COORDINATE WITH MECHANICAL AND ELECTRICAL CONTRACTORS THE LOCATION OF ALL ACCESS PANELS SO AS TO ALLOW FOR PROPER EQUIPMENT ACCESSIBILITY, MAINTENANCE AND/OR OPERATION OF THE BUILDING SYSTEMS PRIOR TO THE START OF WORK. THE OMISSIONS OF ANY OR ALL ACCESS PANELS DOES NOT RELIEVE THE CONTRACTOR OF THE RESPONSIBILITY FROM PROVIDING AND INSTALLING SUCH PANELS OR DOORS. ACCESS PANELS IN RATED ELEMENTS SHALL HAVE THE SAME FIRE RATING.
- CONTRACTOR TO PROVIDE ACCESS PANELS FOR ALL A/C FIRE DAMPERS WHERE APPLICABLE.
- CONTRACTOR SHALL PAINT ALL VISIBLE SURFACES OF FACTORY PRIMED OR FACTORY PAINT FINISHED EQUIPMENT, A.C. GRILLS OR REGISTERS, COVERS, ETC. UNLESS SPECIFICALLY NOTED OTHERWISE VERIFY AND COORDINATE COLORS WITH INTERIOR DESIGN AND ARCHITECT, SEE PAINT SPEC.
- BEFORE INSTALLATION, THE CONTRACTOR SHALL COORDINATE WITH THE ARCHITECT THE EXACT MOUNTING LOCATION AND HEIGHTS OF ALL SWITCHES, WALL RECEPTACLES, PLUGS, THERMOSTATS AND OTHER WALL MOUNTED FIXTURES.
- ALL INTERIOR AND EXTERIOR JOINTS BETWEEN DIFFERENT MATERIALS OR FINISHES SHALL RECEIVE A BEAD OF CAULKING OR FORM A REVEAL TO MATCH COLOR OF ADJACENT SURFACE. COORDINATE COLORS WITH ARCHITECT.
- CONTRACTOR SHALL BE RESPONSIBLE FOR REMOVING ALL DEBRIS AND CONSTRUCTION MATERIAL FROM THE SITE. CONTRACTOR SHALL ALSO BE RESPONSIBLE FOR PROPERLY CLEANING ALL AREAS PRIOR TO FINAL ACCEPTANCE BY THE OWNER INCLUDING BUT NOT LIMITED TO WINDOWS, FLOORS, CARPETS, WALLS, DOORS, EQUIPMENT, ETC.
- UPON COMPLETION OF THIS PROJECT, THE CONTRACTOR SHALL GIVE TO THE OWNER A COMPLETE SET OF AS-BUILT CIVIL, LANDSCAPE, ARCHITECTURAL, MECHANICAL, PLUMBING, ELECTRICAL AND FIRE PROTECTION DRAWINGS ALONG WITH THE WRITTEN DRAWING, OPERATION AND MAINTENANCE MANUALS OF ALL EQUIPMENT AND FINISHES INSTALLED. THE CONTRACTOR SHALL MAINTAIN A CURRENT SET OF AS-BUILT DRAWINGS AND SPECIFICATIONS. INFORMATION SHALL BE RECORDED BY CONTRACTOR AS CONSTRUCTION PROGRESSES AND REVIEWED FOR COMPLETENESS AT EACH REQUISITION REQUEST. REFER TO PROJECT MANUAL.
- CONTRACTOR SHALL PROVIDE PROPER SAFEGUARDS IN COMPLIANCE WITH THE LIFE SAFETY PLANS DURING ALL PHASES OF CONSTRUCTION, IN ACCORDANCE WITH THE 2017 FBC AND WITH THE 6TH ED. FFPC.
- CONTRACTOR TO INSTALL BARRIERS AS NECESSARY AND REQUIRED AROUND PERIMETER OF CONSTRUCTION LIMITS TO PROTECT THE PUBLIC. EGRESS FROM THE EXISTING BUILDING SHALL NOT BE REDUCED OR LIMITED PER THE LIFE SAFETY PLANS AND/OR DETOURED ROUTE. REFER TO THE 2017 FBC.
- WHERE EXISTING WALLS ARE TO BE PATCHED AND FILLED TO "LIKE NEW" CONDITION, THEY SHALL BE MADE TO MATCH THICKNESS AND FINISH OF ADJACENT CONSTRUCTION. FINISHES SHALL BE REPLACED TO THE END OF EACH WALL OR NEAREST CONSTRUCTION JOINT.
- ALL PIPING SHALL BE SLEEVED THROUGH SLAB. CONTRACTOR SHALL FULLY SEAL SPACE AROUND PIPES WITH A 2-HOUR U.L. FIRE STOPPING MATERIAL. REFER TO SPECIFICATIONS.
- CONTRACTOR TO FURNISH AND INSTALL ALL METAL AND WOOD BLOCKING REQUIRED FOR WALL MOUNTED OR BRACED FIXTURES, CHALKBOARDS, MARKER BOARDS, TACKBOARDS, MILLWORK, SHELVES, TOILET FIXTURES, AND ACCESSORIES OR BY OTHER ITEMS DESCRIBED IN INTERIOR DESIGN AND ARCHITECTURAL DRAWINGS. BLOCKING SHALL BE CONSTRUCTED TO SUPPORT THE IMPOSED LOAD.
- CONTRACTOR TO PROVIDE AN ITEMIZED LIST OF ALL REMOVED ITEMS, WHICH SHALL BE STORED FOR SAFETY UNTIL COMPLETION OF THE CONSTRUCTION.
- CONTRACTOR TO PROVIDE A SAFETY PLAN TO CLEARLY DELINEATE AREAS FOR CONSTRUCTION, SAFETY BARRIERS, EXITS, CONSTRUCTION TRAFFIC DURING THE VARIOUS PHASES AND WHEN CONDITIONS CHANGE, AS PER THE 2017 FBC.
- UNLESS OTHERWISE NOTED, CEMENT BOARD/IMPACT BOARD/ABUSE RESISTANT BOARD WHERE INDICATED SHALL EXTEND UP TO 6" ABOVE FINISH CEILING AND REGULAR GYPSUM WALLBOARD (TYPE "X" FOR FIRE RATED WALL) FROM 6" ABOVE FINISH CEILING UP TO UNDERSIDE OF STRUCTURE OR DECK.
- WHERE STAINLESS STEEL SCUPPERS AND CONDUCTOR BOXES ARE PROVIDED, (IN LIEU OF PVC) NO PAINTING WILL BE REQUIRED.
- ALL EXPOSED PIPING SHALL BE PAINTED WITH COLOR CODE: INCLUDING MEP PIPES AND CONDUITS IN MECHANICAL, ELECTRICAL ROOMS AND CHILLER PLANT; COORDINATE COLORS WITH OCP'S MAINTENANCE DEPT. COLOR CODING IN CONCEALED SPACES NOT REQUIRED.
- DEFERRED SUBMITTAL ITEMS: GENERAL CONTRACTOR SHALL PROVIDE SHOP DRAWINGS FOR REVIEW AND APPROVAL FOR HVAC, SHEET METAL, LIGHTING, WINDOWS, EXTERIOR DOORS INCLUDING FRAMES & HARDWARE, EXTERIOR LOUVERS, GUARDRAILS, EXTERIOR SOFFITS, ROOF EQUIPMENT, ROOF CURBS, ROOF HATCH

CHECKED BY:	DRAWN BY:
LR	C.V.

CONSULTANT INFO:

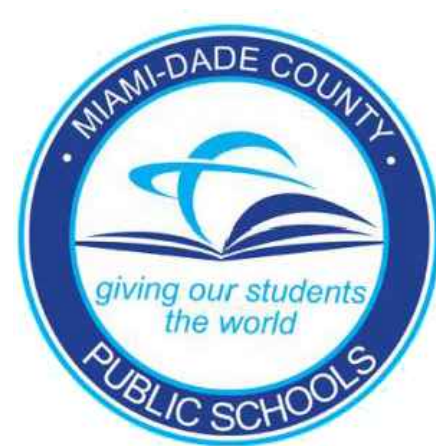


NEW ELEMENTARY SCHOOL (K-5)

VENETIAN PARC WEST

SOUTHWEST 157th AVENUE and 174th STREET
MIAMI, FL. 33187

MDCPS PROJECT No. 01892600

KEY PLAN

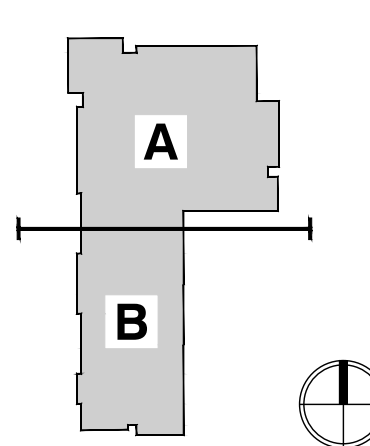

CONSULTANT INFO:



RODRIGUEZ
ARCHITECTS
INCORPORATED
2121 PONCE DE LEON BLVD. STE. 1010
CORAL GABLES, FL. 33134
TEL: (305) 448-3373
FAX: (305) 448-3374

A A C — 0 0 1 9 3 3

RAI

REVISIONS:

02/14/2020 BUILDING DEPARTMENT COMMENTS

DRAWING TITLE:

ABBREVIATIONS & GENERAL NOTES

SCALE: AS NOTED

ISSUE DATE: 12/16/19

PROJECT NO: 1906

SHEET:

GN-101

INDEX OF SHEETS

C-1 COVER SHEET
C-2 SITE GEOMETRY PLAN
C-3 PAVING, GRADING AND DRAINAGE PLAN
C-4 PAVEMENT MARKINGS AND SIGNAGE PLAN
C-5 PAVING AND DRAINAGE DETAILS
C-6 PAVING AND DRAINAGE DETAILS
C-7 STORM WATER POLLUTION PREVENTION PLAN

DEMOLITION NOTES:

- UNLESS OTHERWISE NOTED, ALL EXISTING IMPROVEMENTS WITHIN THE LIMITS OF WORK SHALL BE REMOVED IN THEIR ENTIRETY.
- ASPHALT PAVEMENT DESIGNATED FOR DEMOLITION SHALL BE REMOVED AND DISPOSED OF OFF-SITE AT AN APPROVED LOCATION. SAW CUT ALL PAVEMENT EDGES WHERE EXISTING PAVEMENT IS TO REMAIN.
- IN GREEN AREAS, EXISTING LIMEROCK SUBBASE SHALL BE SCARIFIED TO ITS FULL DEPTH AND SHAPED TO THE LINES AND GRADES SHOWN IN THESE DRAWINGS.
- ALL EXISTING DRAINAGE IMPROVEMENTS WITHIN THE LIMITS OF WORK, IF ANY, SHALL BE REMOVED, INCLUDING STRUCTURES, PIPES, AND FRENCH DRAINS.

TRENCH SAFETY ACT

- TRENCHING: THE CONTRACTOR MUST ASSURE COMPLIANCE WITH THE "TRENCH SAFETY ACT". THE CURRENT TRENCH SAFETY STANDARDS IN EFFECT ARE OCCUPATIONAL SAFETY AND HEALTH ADMINISTRATIONS (OSHA) EXCAVATING SAFETY STANDARDS 29 C.F.R. PART 1926.650 SUBPART P.

GENERAL NOTES:



- VERTICAL CONTROL POINTS AND ALL ELEVATIONS ARE BASED ON 1929 NGVD DATUM.
- THE CONTRACTOR SHALL CONFIRM ALL HORIZONTAL AND VERTICAL CONTROL POINTS PRIOR TO USE. THE CONTRACTOR SHALL CONFIRM ALIGNMENT AND ELEVATIONS OF ADJACENT WORK PRIOR TO BEGINNING CONSTRUCTION. ALL DISCREPANCIES SHALL BE IMMEDIATELY BROUGHT TO THE OWNER'S ATTENTION.
- ALL EXISTING UTILITIES SHALL REMAIN IN SERVICE, UNLESS OTHERWISE NOTED.
- USE EXTREME CAUTION NEAR ALL UTILITIES, CABLES, CONDUITS, AND MANHOLES. CONTRACTOR TO PROVIDE PROTECTION DURING CONSTRUCTION TO ASSURE SERVICE AT ALL TIMES. CONTRACTOR SHALL COORDINATE ALL SCHEDULES WITH FIELD REPRESENTATIVE PRIOR TO WORKING AROUND UTILITIES.
- CONTRACTOR SHALL BE RESPONSIBLE FOR BECOMING FAMILIAR WITH CURRENT SITE CONDITIONS AND SHALL REPORT ANY DISCREPANCIES ON THE PLANS TO THE ENGINEER PRIOR TO COMMENCING WORK.
- ALL CONSTRUCTION LAYOUT SHALL BE THE RESPONSIBILITY OF THE CONTRACTOR. THE CONTRACTOR SHALL BE RESPONSIBLE FOR ESTABLISHING THE WORK LIMIT LINES AS SHOWN ON THE PLANS AND SHALL WORK WITHIN THE LIMITS AND DIMENSIONS SHOWN. ALL PAVEMENT DIMENSIONS ARE TO THE EDGE OF PAVEMENT. ANY DEVIATION FROM THE PLANS SHALL REQUIRE WRITTEN APPROVAL FROM THE ENGINEER PRIOR TO EXECUTING WORK.
- GRADING SHALL CONSIST OF ALL EXCAVATION, BACKFILLING, SHAPING AND SLOPING NECESSARY FOR THE CONSTRUCTION, PREPARATION AND COMPLETION OF ALL WORK AND OTHER AREAS, ALL IN ACCORDANCE WITH THE LAYOUT AND GRADES SHOWN ON THESE DRAWINGS. SAWCUT ALL PAVEMENT EDGES WHERE EXISTING PAVEMENT IS TO REMAIN.
- CONTRACTOR SHALL BE RESPONSIBLE FOR PROTECTING AND RESTORING ALL ADJACENT IMPROVEMENTS. CONTRACTOR SHALL BE RESPONSIBLE FOR RESETTING ALL DISTURBED EXISTING MANHOLE COVERS, VALVE BOXES, BLOW-OFF RISERS, ETC. TO NEW ELEVATIONS, AS REQUIRED, WHETHER SPECIFICALLY SHOWN ON DRAWINGS OR NOT.
- THE CONTRACTOR SHALL NOTIFY ALL UTILITY COMPANIES THAT MAY BE AFFECTED BY THE PROPOSED WORK, PRIOR TO THE START OF ANY CONSTRUCTION, TO ARRANGE FOR PHYSICAL LOCATION AND ELEVATION OF ALL UNDERGROUND IMPROVEMENTS. IT IS THE CONTRACTOR'S RESPONSIBILITY TO PROVIDE THE UTILITY COMPANY SUFFICIENT NOTICE TO SCHEDULE ANY RELOCATION OF THEIR UTILITIES. THE CONTRACTOR SHALL BE RESPONSIBLE FOR SUPPORT OF ANY UTILITY THAT MAY BE IN CONFLICT WITH OR ENDANGERED BY THE PROPOSED WORK.
- ALL OVERHEAD OR SURFACE STRUCTURES AND UTILITIES ENCOUNTERED ARE TO BE CAREFULLY PROTECTED FROM DAMAGE OR DISPLACEMENT. ALL DAMAGE TO SUCH STRUCTURES SHALL BE COMPLETELY REPAIRED WITHIN THE TIME FRAME OF THE CONSTRUCTION. THE OWNER RESERVES THE RIGHT TO REMEDY SUCH DAMAGE BY ORDERING OUTSIDE PARTIES TO MAKE SUCH REPAIRS AT THE EXPENSE OF THE CONTRACTOR.
- COMPLETE "AS-BUILT" INFORMATION RELATIVE TO LOCATION, SIZE AND DEPTH OF THE PROPOSED PIPES, STRUCTURES, AND OTHER IMPROVEMENTS SHALL BE ACCURATELY RECORDED. THIS INFORMATION SHALL BE SUBMITTED TO THE ENGINEER AS A CADD FILE AND AS A DRAWING SIGNED AND SEALED BY A PROFESSIONAL LAND SURVEYOR REGISTERED IN THE STATE OF FLORIDA AT THE CONTRACTOR'S EXPENSE.
- THE UNDERGROUND UTILITIES SHOWN HEREON ARE BASED ON EXISTING UTILITY PLANS. NO SUBSURFACE VERIFICATION OF THE UTILITIES WAS MADE. SOME UTILITIES MAY NOT BE REFLECTED IN THESE PLANS. BEFORE EXCAVATION OR CONSTRUCTION, CONTACT THE SUNSHINE ONE CALL SERVICE #811 AND THE APPROPRIATE UTILITY COMPANIES FOR FIELD VERIFICATION. SUBSURFACE CASINGS, DUCT BANKS, FOOTINGS FOUNDATIONS, AND OTHER SUBSURFACE FEATURES ARE NOT LOCATED OR SHOWN HEREON ARE TO BE VERIFIED BY CONTRACTOR BEFORE COMMENCING ANY WORK.
- PROVIDE 6 FOOT VINYL VISUAL BARRIER ON ALL FENCING AT CONSTRUCTION LIMITS.
- THE CONTRACTOR SHALL BE RESPONSIBLE FOR MAINTAINING THE INTEGRITY AND MAKING THE REPAIRS OF EXISTING PAVEMENT, SIDEWALKS, PIPES, CONDUITS, CURBS, CABLES, ETC. WHETHER OR NOT SHOWN ON THE PLANS, DAMAGED AS A RESULT OF THE CONTRACTOR'S OPERATIONS AND/OR THOSE OF HIS SUBCONTRACTORS, AND SHALL RESTORE THEM PROMPTLY TO THE ORIGINAL CONDITIONS OR BETTER AT NO ADDITIONAL EXPENSE TO THE OWNER. CONTRACTOR SHALL REPORT ANY DAMAGED SIDEWALK, DRIVEWAY, ETC., PRIOR TO BEGINNING WORK IN ANY AREA.
- EXISTING WATER METERS, UTILITY POLES & GUY WIRES AND OTHER UTILITIES WITHIN THE LIMITS OF CONSTRUCTION SHALL BE REMOVED OR RELOCATED UNLESS OTHERWISE NOTED.
- ALL WORK SHALL CONFORM TO ALL APPLICABLE CODES OF FLORIDA BUILDING CODE 2014, STATE REQUIREMENTS FOR EDUCATIONAL FACILITIES (SREF), MIAMI-DADE COUNTY PUBLIC SCHOOLS DESIGN CRITERIA, MIAMI-DADE COUNTY DEPARTMENT OF ENVIRONMENTAL RESOURCES (DERM) STANDARDS AND DETAILS, MIAMI-DADE COUNTY WATER AND SEWER DEPARTMENT (M-DWASD) STANDARDS AND DETAILS AND FLORIDA DEPARTMENT OF TRANSPORTATION STANDARDS AND DETAILS.
- WHERE HEAVY MACHINERY AS IS USED FOR EARTH MOVING OR SCRAPING IS REQUIRED TO WORK ON SCHOOL BOARD'S OCCUPIED SITE, THE WORK SHALL BE SEPARATED FROM OCCUPANTS BY SECURE DOUBLE BARRIERS WITH A DISTANCE OF 10' IN BETWEEN.
- EROSION AND SOIL CONTROL DEVICES AND BEST MANAGEMENT PRACTICES SHALL BE IN ACCORDANCE WITH FDEP-FLORIDA STORMWATER EROSION AND SEDIMENTATION CONTROL INSPECTOR'S MANUAL.
- CONTRACTOR SHALL SUBMIT SHOP DRAWINGS FOR ALL DRAINAGE COMPONENTS FOR ENGINEER'S APPROVAL.
- BEFORE CONSTRUCTION, CONTRACTOR SHALL PERFORM G.P.R. (GROUND PENETRATION RADAR) TESTS TO IDENTIFY ALL EXISTING UTILITIES WITHIN PROJECT LIMITS & NOTIFY ARCHITECTS/ENGINEERS OF ANY CONFLICTS PRIOR TO EXCAVATION.

SITE DATA

FLOOD ZONE FIRM MAP PANEL No. = 12086C0580L
ZONE "X", DATED: 09-11-2009
BASE FLOOD ELEVATION = N/A
WATER TABLE ELEVATION OCT. H.W. = (+) 5.5 NGVD
FLOOD CRITERIA ELEVATION = (+) 8.0 NGVD

UNDERGROUND DIGGING NOTE:

CONTRACTOR SHALL USE EXTREME CAUTION WHEN EXCAVATING. CONTRACTOR SHALL REMAIN 2 FEET AWAY FROM THE LOCATED MARKS WITH THE MACHINERY. IF IT'S NECESSARY TO EXCAVATE WITHIN THE 2 FOOT TOLERANCE ZONE, CONTRACTOR MUST HAND DIG, SOFT DIG, OR USE NON-INVASIVE MEANS TO EXPOSE AND PROTECT THE EXISTING FACILITIES AS REQUIRED BY LAW.

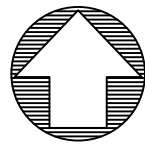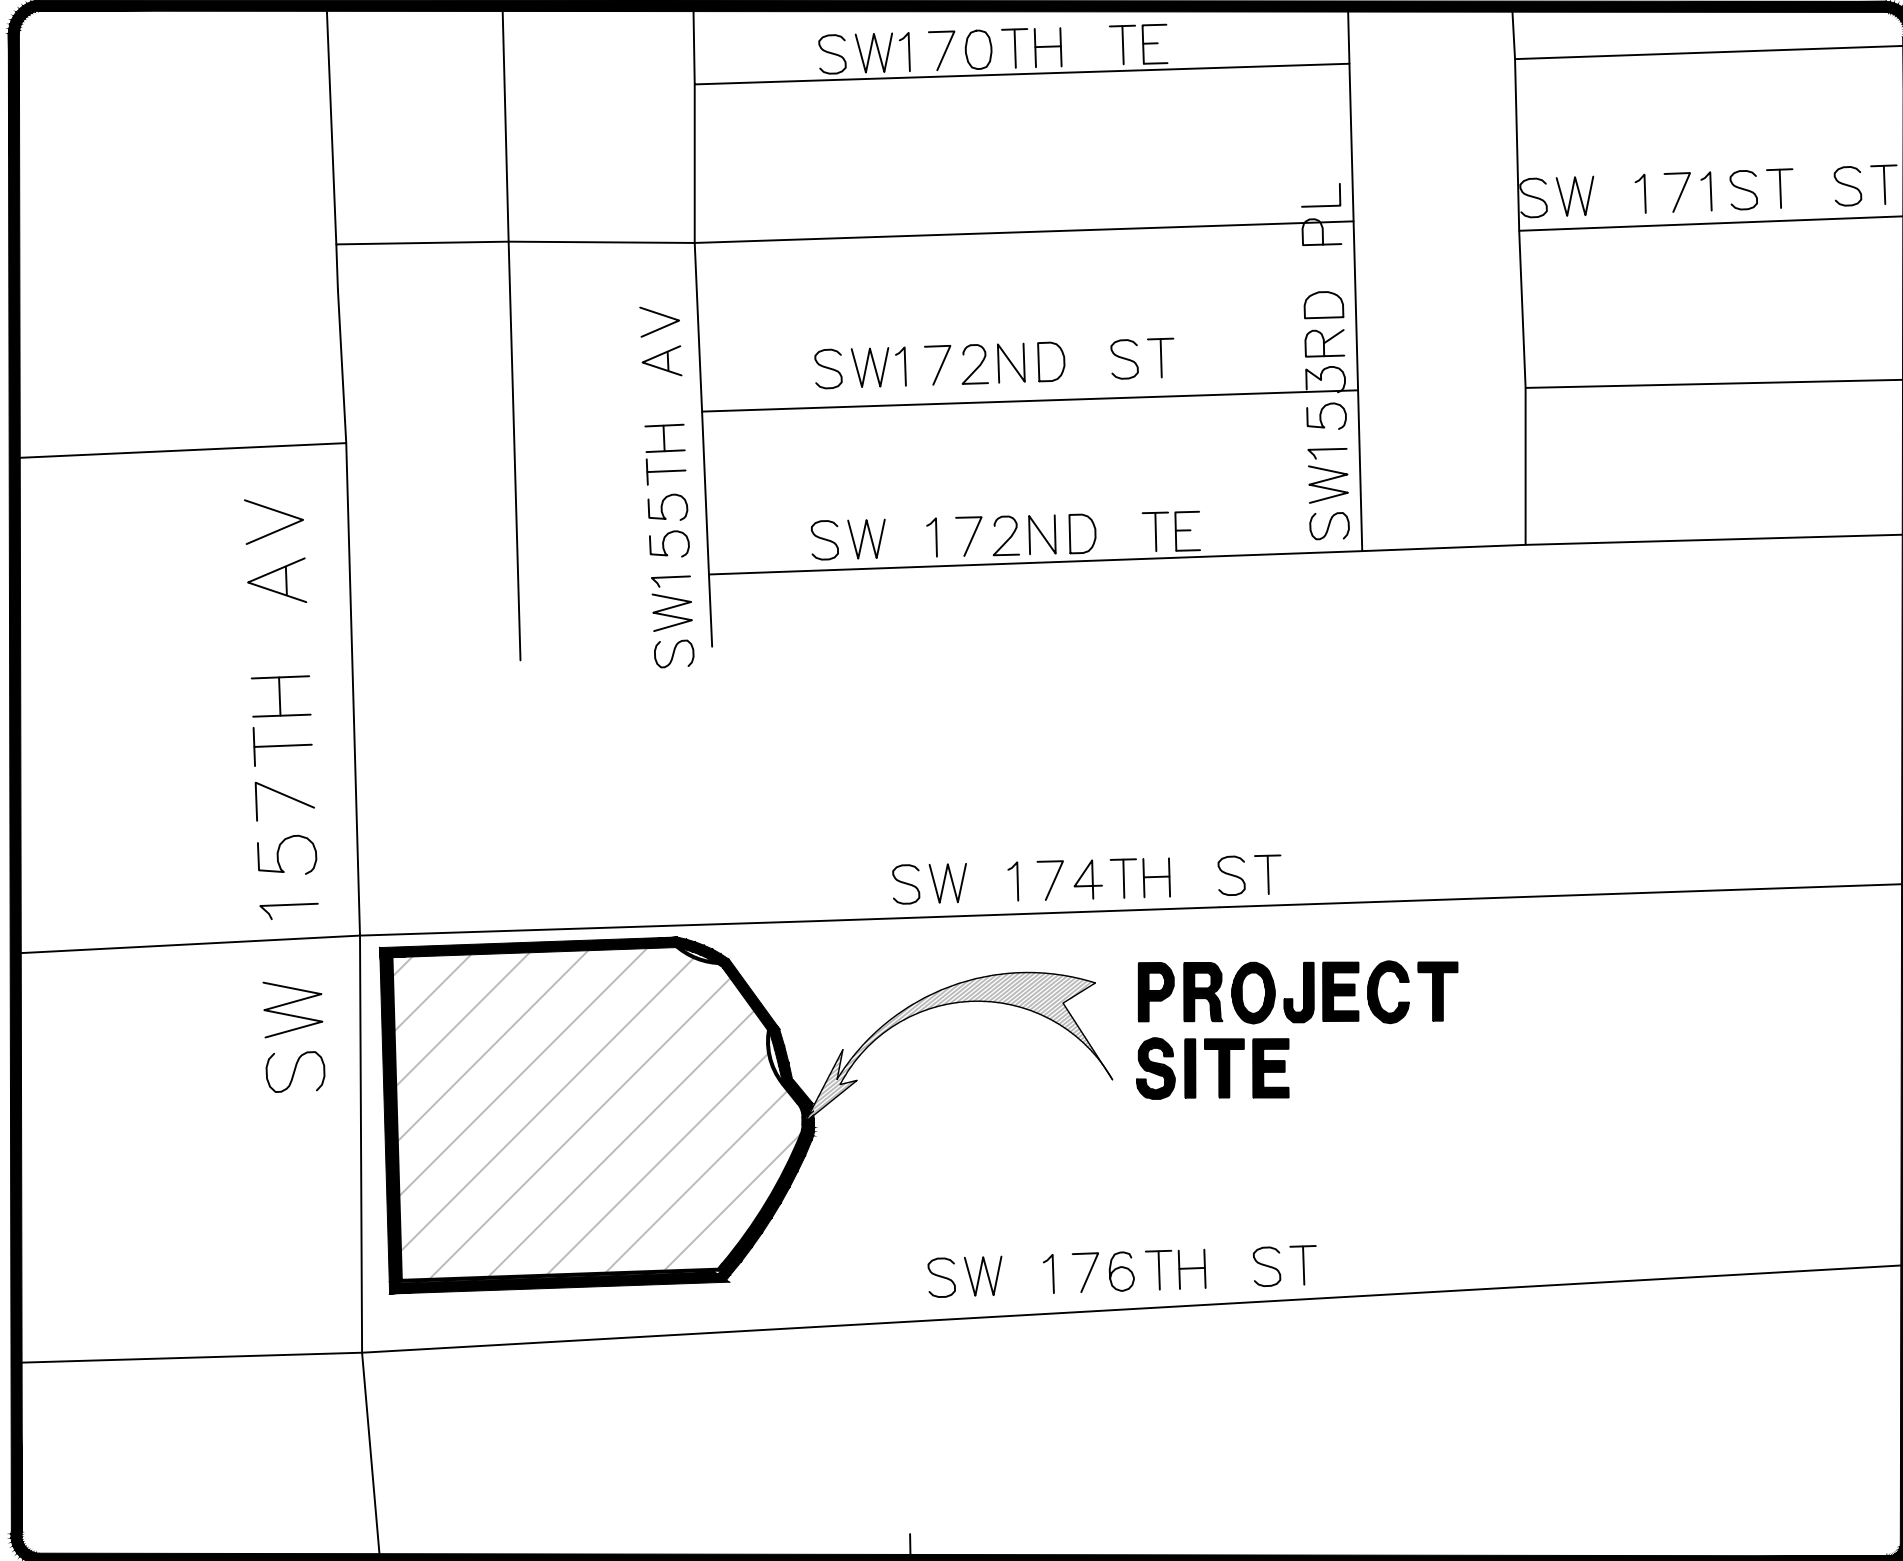

LOCATION MAP

SCALE: 1"=300'

FOLIO# 30-5933-035-4090


LEGAL DESCRIPTION:

TRACT "Q" OF VENETIAN PARC WEST, ACCORDING TO THE PLAT THEREOF, AS RECORDED IN PLAT BOOK 170, PAGE 27, OF THE PUBLIC RECORDS OF MIAMI-DADE COUNTY, FLORIDA, FORMERLY DESCRIBED AS:

A PORTION OF THE WEST 1/2 OF SECTION 33, TOWNSHIP 55 SOUTH, RANGE 39 EAST, MIAMI-DADE COUNTY, FLORIDA, BEING MORE PARTICULARLY DESCRIBED AS FOLLOWS:

COMMENCE AT THE WEST 1/4 CORNER OF SAID SECTION 33; THENCE N87°59'15"E, ALONG THE SOUTH LINE OF THE NORTHWEST 1/4 OF SAID SECTION 33, FOR A DISTANCE OF 40.00 FEET TO THE POINT OF BEGINNING OF THE HEREINAFTER DESCRIBED PARCEL OF LAND; THENCE N01°40'01"W, ALONG A LINE 40 FEET EAST OF AND PARALLEL WITH THE WEST LINE OF THE NORTHWEST 1/4 OF SAID SECTION 33, FOR A DISTANCE OF 499.39 FEET; THENCE N87°59'15"E FOR A DISTANCE OF 442.70 FEET TO THE INTERSECTION WITH THE ARCH OF A CIRCULAR CURVE TO THE LEFT, CONCAVE TO THE NORTHEAST, A RADIAL LINE FROM SAID POINT BEARS N43°03'46"E; THENCE SOUTHEASTERLY AND EASTERLY ALONG THE ARCH OF SAID CURVE, HAVING FOR ITS ELEMENTS A RADIUS OF 108.33 FEET; THROUGH A CENTRAL ANGLE OF 43°59'17" FOR AN ARC DISTANCE OF 82.54 FEET TO A POINT ON A NON-TANGENTIAL LINE; THENCE S37°27'58"E FOR A DISTANCE OF 121.94 FEET TO THE INTERSECTION WITH THE ARC OF A CIRCULAR CURVE TO THE LEFT, CONCAVE TO THE NORTHEAST, A RADIAL LINE FROM SAID POINT BEARS S75°42'59"E; THENCE SOUTHEASTERLY ALONG THE ARC OF SAID CURVE, HAVING FOR ITS ELEMENTS A RADIUS OF 105.00 FEET, THROUGH A CENTRAL ANGLE OF 52°59'28" FOR AN ARC DISTANCE OF 97.11 FEET TO A POINT OF TANGENCY; THENCE S38°42'26"E FOR A DISTANCE OF 39.12 FEET TO A POINT OF CURVATURE OF A CIRCULAR CURVE TO THE RIGHT, CONCAVE TO THE SOUTHWEST; THENCE SOUTHEASTERLY AND SOUTHERLY ALONG THE ARC OF SAID CURVE, HAVING FOR ITS ELEMENTS A RADIUS OF 35.00 FEET; THROUGH A CENTRAL ANGLE OF 38°02'31" FOR AN ARC DISTANCE OF 23.24 FEET TO A POINT OF TANGENCY; THENCE S00°39'55"E FOR A DISTANCE OF 11.66 FEET TO A POINT OF CURVATURE OF A CIRCULAR CURVE TO THE RIGHT, CONCAVE TO THE NORTHWEST; THENCE SOUTHERLY AND SOUTHWESTERLY ALONG THE ARC OF SAID CURVE, HAVING FOR ITS ELEMENTS A RADIUS OF 40.00 FEET, THROUGH A CENTRAL ANGLE OF 22°59'29" FOR AN ARC DISTANCE OF 16.05 FEET TO A POINT OF COMPOUND CURVATURE OF A CIRCULAR CURVE TO THE RIGHT, CONCAVE TO THE NORTHWEST; THENCE SOUTHWESTERLY ALONG THE ARC OF SAID CURVE, HAVING FOR ITS ELEMENTS A RADIUS OF 769.80 FEET; THROUGH A CENTRAL ANGLE OF 17°45'15" FOR AN ARC DISTANCE OF 238.54 FEET TO A POINT OF REVERSE CURVATURE OF A CIRCULAR CURVE TO THE LEFT, CONCAVE TO THE SOUTHEAST; THENCE SOUTHWESTERLY ALONG THE ARC OF SAID CURVE, HAVING FOR ITS ELEMENTS A RADIUS OF 100.00 FEET; THROUGH A CENTRAL ANGLE OF 5°41'42" FOR AN ARC DISTANCE OF 9.94 FEET TO A POINT ON A LINE 10.73 FEET SOUTH OF AND PARALLEL WITH THE SOUTH LINE OF THE NORTHWEST 1/4 OF SAID SECTION 33; THENCE S87°59'15"W ALONG THE LAST DESCRIBED LINE FOR A DISTANCE OF 497.24 FEET TO A POINT ON A LINE 40.00 FEET EAST OF AND PARALLEL WITH THE WEST LINE OF SAID SECTION 33; THENCE N01°16'16"W, ALONG THE LAST DESCRIBED LINE FOR A DISTANCE OF 10.73 FEET TO THE POINT OF BEGINNING. FOLIO NO. 30-5933-035-4090


CONSULTANT INFO:

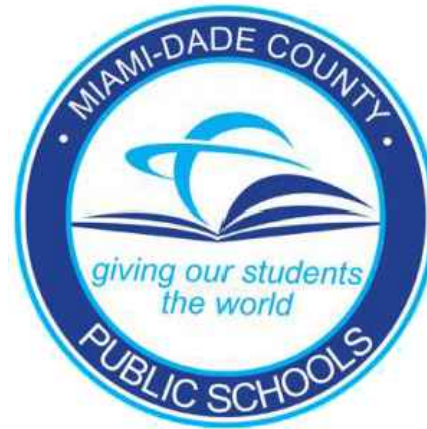

VENETIAN PARC WEST K-5 SCHOOL

SOUTHWEST 157th AVENUE and 174th STREET
MIAMI, FL. 33187
MDCPS PROJECT No. 01892600

KEY PLAN

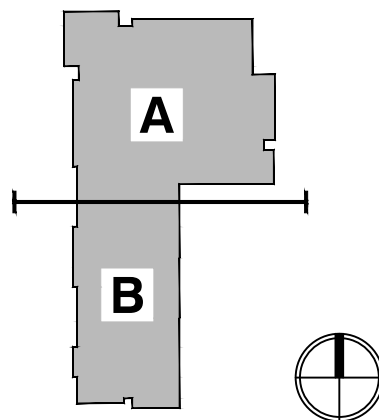


CONSULTANT INFO:

Jorge R. Avinó
PE No. 22207

RODRIGUEZ ARCHITECTS INCORPORATED
2121 PONCE DE LEON BLVD. STE. 1010
CORAL GABLES, FL. 33134
TEL: (305) 448-3373
FAX: (305) 448-3374

A A C — 0 0 1 9 3 3

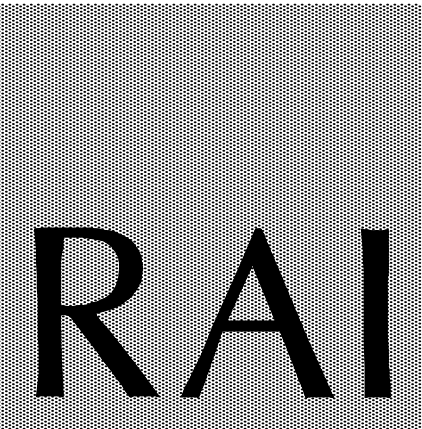

REVISIONS:


NO.	DATE	DESCRIPTION
02.14.20	BCC COMMENTS	

DRAWING TITLE:

COVER SHEET

SCALE AS NOTED

ISSUE DATE	PROJECT NO.
12.16.19	1906
SHEET:	C-1

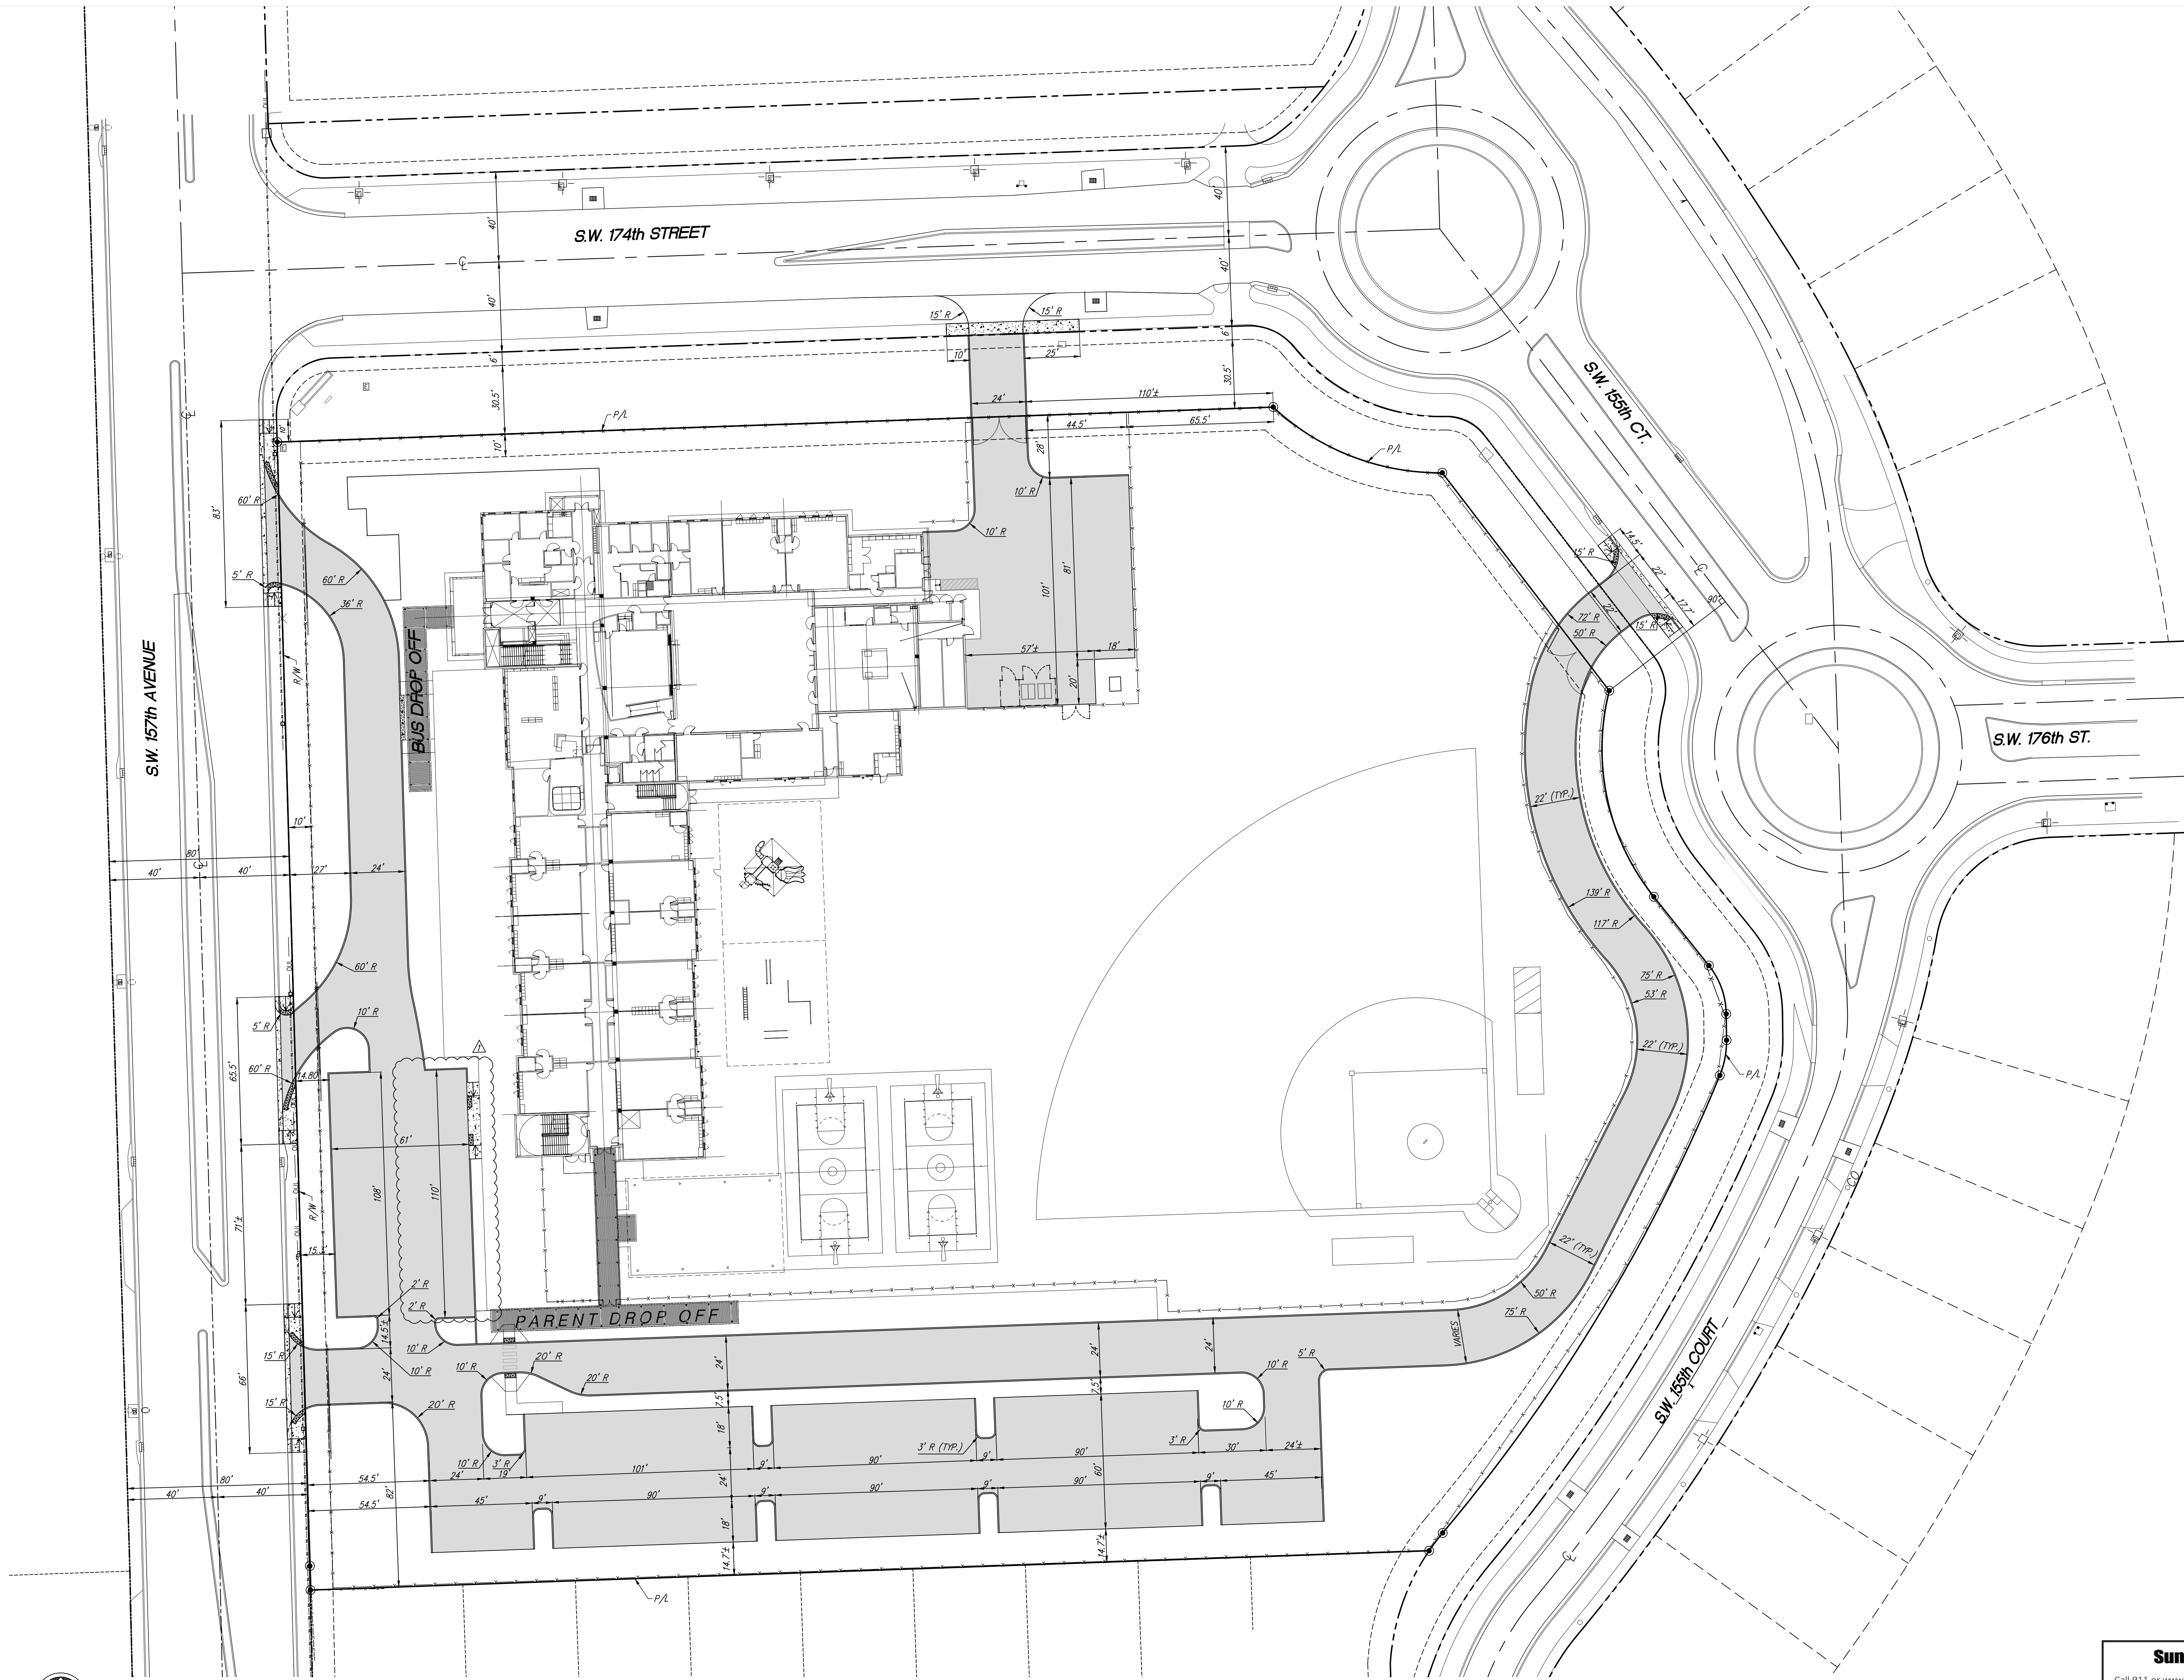


SITE GEOMETRY PLAN
SCALE: 1" = 30'

Sunshine811
Call 811 or www.sunshine811.com two full business days before digging to have utilities located and marked.
Check positive response codes before you dig!

ENGINEER'S CERTIFICATION:
I HEREBY CERTIFY: That this plan was prepared under my direction and to the best of my knowledge and belief complies with the intent of the "MANUAL OF UNIFORM STANDARDS FOR DESIGN, CONSTRUCTION AND MAINTENANCE FOR STREETS, AND HIGHWAYS", as adopted by the State of Florida Legislature, Chapter 72-328 F.S.

CHECKED BY: N.V.		DRAWN BY: C.O.	
---------------------	--	-------------------	--


CONSULTANT INFO:

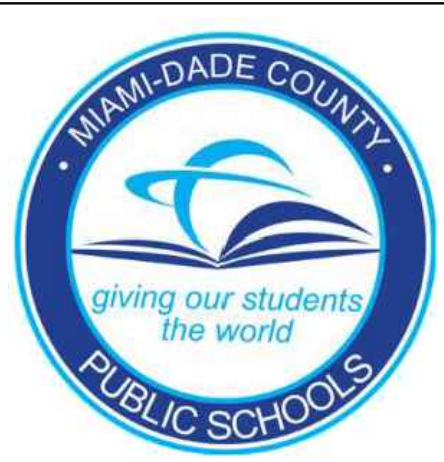

VENETIAN PARC WEST K-5 SCHOOL

SOUTHWEST 157th AVENUE and 174th STREET
MIAMI, FL. 33187
MDCPS PROJECT No. 01892600

KEY PLAN

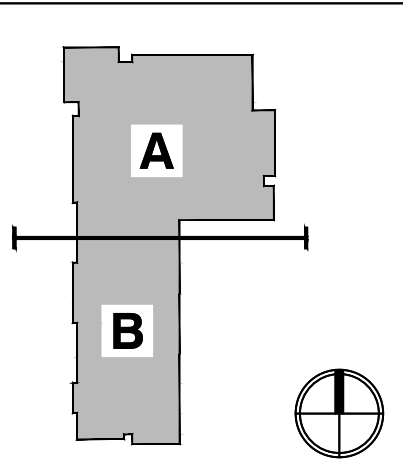

CONSULTANT INFO:


Jorge R. Avila
PE No. 22207

RODRIGUEZ ARCHITECTS INCORPORATED
2121 PONCE DE LEON BLVD. STE. 1010
CORAL GABLES, FL. 33134
TEL: (305) 448-3373
FAX: (305) 448-3374
A A C — 0 0 1 9 3 3



REVISIONS:	
02.14.20	BCC COMMENTS

DRAWING TITLE: SITE GEOMETRY PLAN	
SCALE AS NOTED	
ISSUE DATE: 12.16.19	PROJECT NO. 1906
SHEET: C-2	

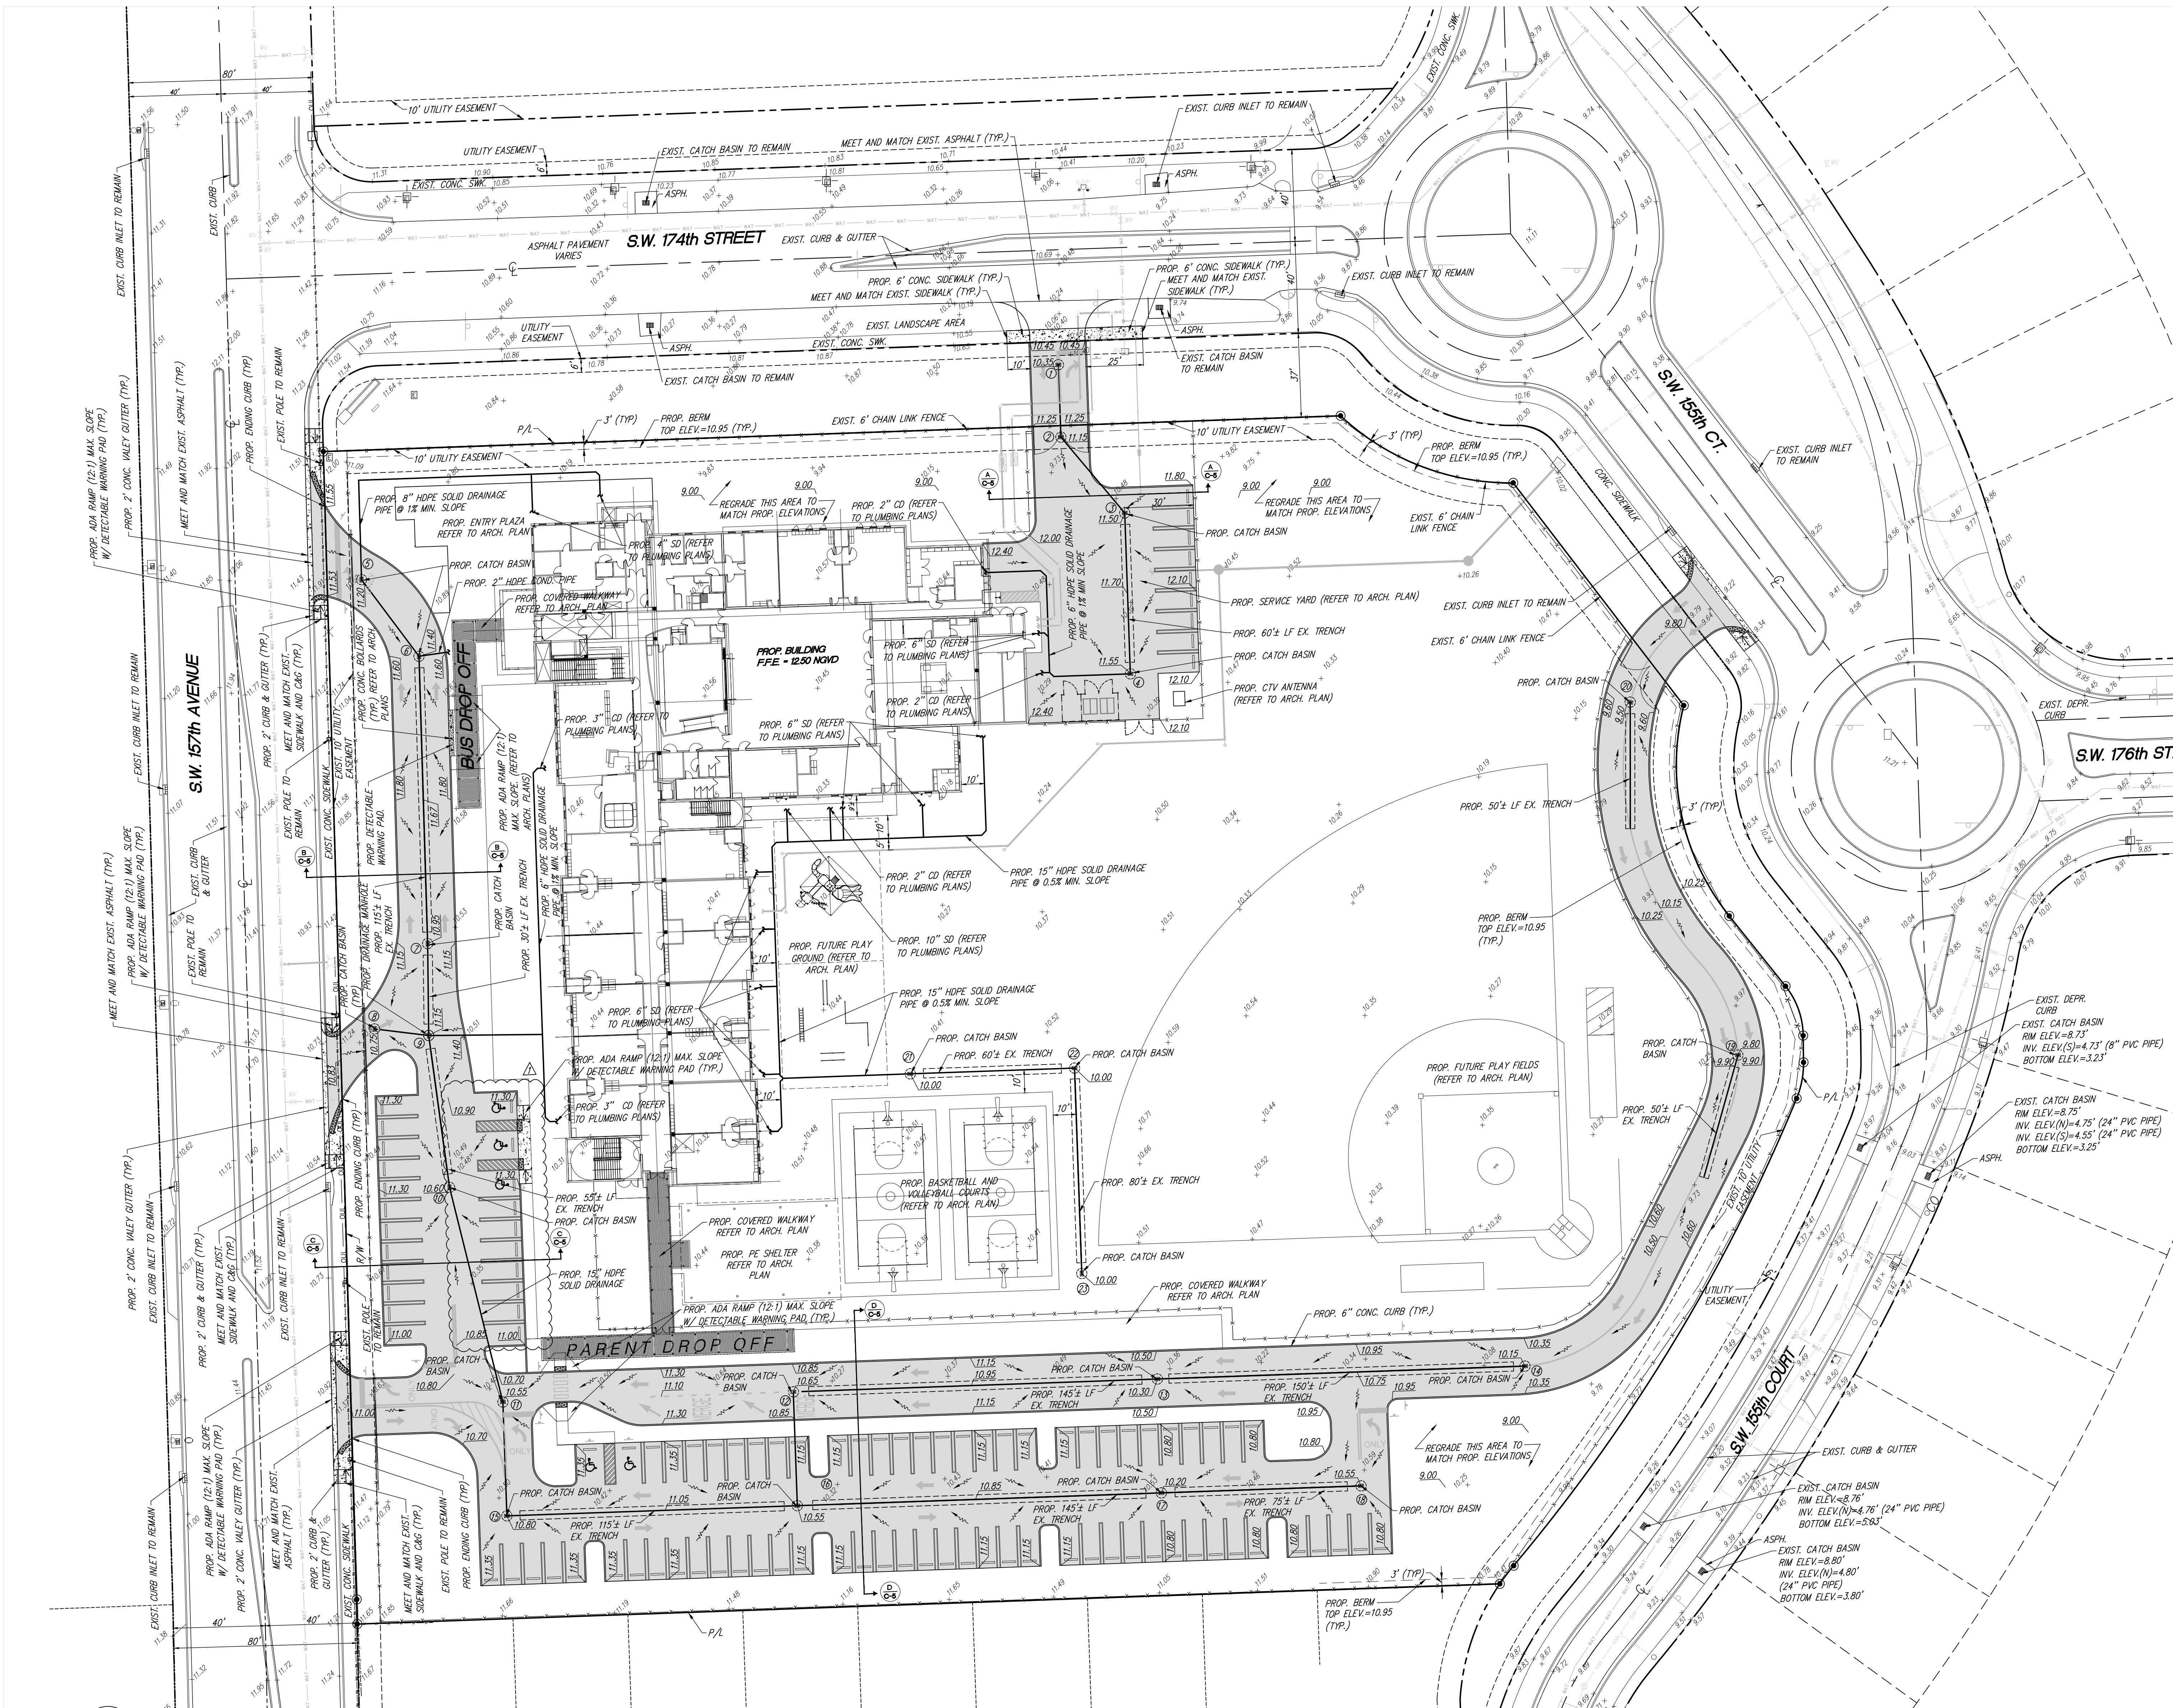

LEGEND:

- EXISTING ELEVATION (NGVD)
- PROPOSED ELEVATION (NGVD)
- DIRECTION OF FLOW
- PROPOSED EXFILTRATION TRENCH
- PROPOSED CATCH BASIN
- PROPOSED CONCRETE
- PROPOSED ASPHALT PAVEMENT
- PROPOSED STRUCTURE NUMBER

DRAINAGE STRUCTURE SCHEDULE

STRUCT. No.	SIZE	RIM ELEV.	PIPE INVERT ELEV.				BOTTOM ELEV.	STRUCTURE TYPE
			N	W	S	E		
CB-1	42"	10.35	-	-	5.90	-	3.90	TYPE "P", USF 4700-6223
CB-2	42"	11.15	5.70	-	5.70 (SE)	-	3.70	TYPE "P", USF 4700-6223
CB-3*	42"	11.50	5.50 (NW)	-	5.50	-	2.00	TYPE "P", USF 4700-6223
CB-4*	42"	11.55	5.50	6.0	-	-	2.00	TYPE "P", USF 4700-6223
CB-5	42"	11.20	5.50	-	5.50 (SE)	-	3.50	TYPE "P", USF 4700-6223
CB-6*	42"	11.40	5.50 (NW)	-	5.50	-	2.00	TYPE "P", USF 4700-6223
CB-7*	48"	10.95	5.50	-	5.50	-	2.00	TYPE "P", USF 4700-6223
CB-8	42"	10.75	-	-	-	5.50	3.50	TYPE "P", USF 4700-6223
MH-9*	48"	11.15	5.50 (NW)	5.50	5.50	6.00	2.00	TYPE "P", USF 310 A
CB-10*	42"	10.60	5.50 (NW)	-	5.50	-	2.00	TYPE "P", USF 4700-6223
CB-11	42"	10.55	5.50 (NW)	-	5.50	-	3.50	TYPE "P", USF 4700-6223
CB-12*	42"	10.65	-	-	5.50	5.50	2.00	TYPE "P", USF 4700-6223
CB-13*	48"	10.30	5.50	-	-	5.50	2.00	TYPE "P", USF 4700-6223
CB-14*	42"	10.15	-	5.50	-	-	2.00	TYPE "P", USF 4700-6223
CB-15*	42"	10.76	5.50	-	-	5.50	2.00	TYPE "P", USF 4700-6223
CB-16*	48"	10.55	5.50	5.50	-	5.50	2.00	TYPE "P", USF 4700-6223
CB-17*	42"	10.20	-	5.50	-	5.50	2.00	TYPE "P", USF 4700-6223
CB-18	42"	10.55	-	5.50	-	-	3.50	TYPE "P", USF 4700-6223
CB-19*	42"	9.80	-	-	5.50 (SW)	-	2.00	TYPE "P", USF 4700-6223
CB-20*	42"	9.50	-	-	5.50 (SE)	-	2.00	TYPE "P", USF 4700-6223
CB-21*	42"	10.00	-	6.00	-	5.50	2.00	TYPE "P", USF 4700-6223
CB-22*	48"	10.00	-	5.50	5.50	-	2.00	TYPE "P", USF 4700-6223
CB-23*	42"	10.00	5.50	-	-	-	2.00	TYPE "P", USF 4700-6223

* BAFFLE REQUIRED

PAVING, GRADING AND DRAINAGE PLAN
SCALE: 1" = 30'

Sunshine811
Call 811 or www.sunshine811.com two full business days before digging to have utilities located and marked.
Check positive response codes before you dig!

ENGINEER'S CERTIFICATION:
I HEREBY CERTIFY: That this plan was prepared under my direction and to the best of my knowledge and belief, complies with the intent of the "MANUAL OF UNIFORM STANDARDS FOR DESIGN, CONSTRUCTION AND MAINTENANCE FOR STREETS, AND HIGHWAYS", as adopted by the State of Florida Legislature, Chapter 72-328 F.S.

REVISIONS:
02.14.20 BCC COMMENTS

DRAWING TITLE:
PAVING, GRADING & DRAINAGE PLAN
SCALE: AS NOTED
ISSUE DATE: 12.16.19
PROJECT NO: 1906
SHEET: C-3

CONSULTANT INFO:

Aviño & ASSOCIATES
1000 N.W. 107th Ave., Suite 100
Miami, FL 33177
(305) 448-3373

VENETIAN PARC WEST K-5 SCHOOL
SOUTHWEST 157th AVENUE and 174th STREET
MIAMI, FL. 33187
MDCPS PROJECT No. 01892600


KEY PLAN

CONSULTANT INFO:

Jorge R. Avila
PE No. 22207

RODRIGUEZ ARCHITECTS INCORPORATED
2121 PONCE DE LEON BLVD. STE. 1010
CORAL GABLES, FL. 33134
TEL: (305) 448-3373
FAX: (305) 448-3374
A A C — 0 0 1 9 3 3

RAI

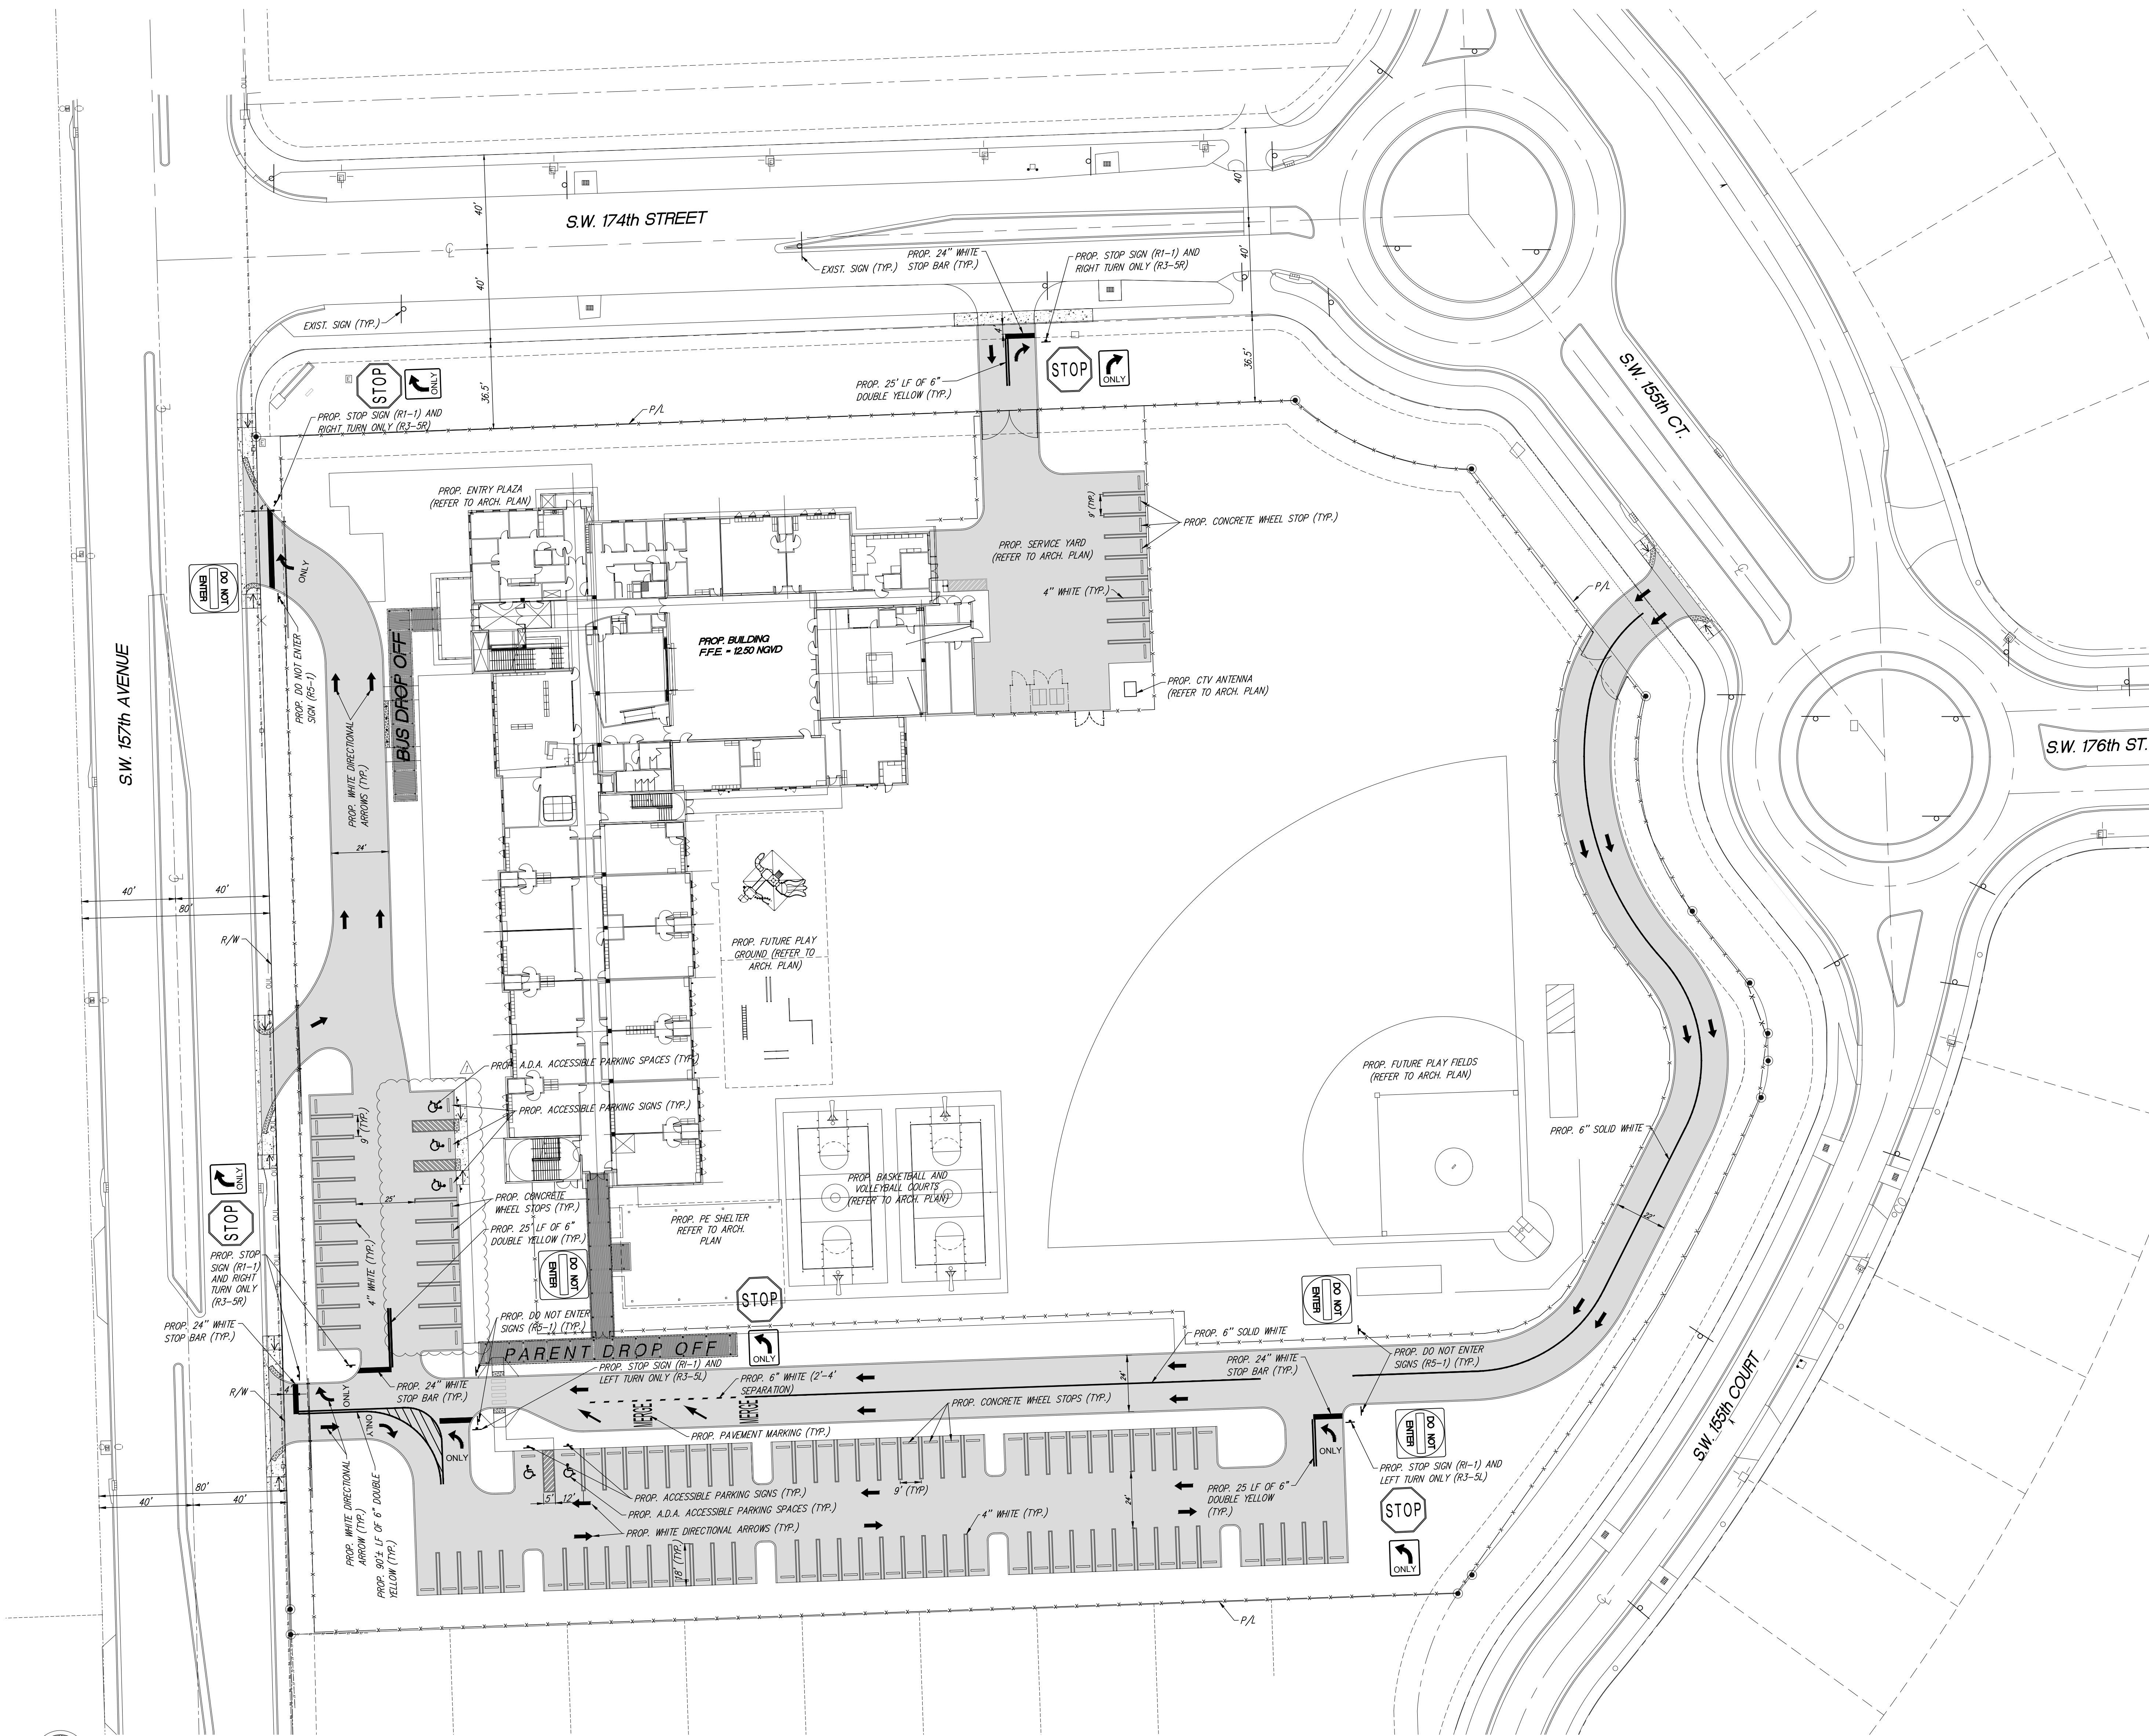

TRAFFIC NOTES & STANDARDS

1. CONTRACTOR SHALL BE RESPONSIBLE FOR THE REMOVAL OF ALL PAVEMENT MARKINGS AND SIGNS CONFLICTING WITH THE PROPOSED CONSTRUCTION.
2. CONTRACTOR SHALL BE RESPONSIBLE FOR THE INSTALLATION OF ALL PAVEMENT MARKINGS AND SIGNS AS SHOWN IN THE PLANS AND APPLICABLE TRAFFIC DESIGN STANDARDS.
3. CONTRACTOR SHALL BE RESPONSIBLE FOR MATCHING EXISTING PAVEMENT MARKINGS AT THE PROJECT.
4. SIGN ASSEMBLY LOCATIONS SHOWN IN THE PLANS WHICH ARE IN CONFLICT WITH STREET LIGHTING, UTILITIES, DRIVEWAYS, PEDESTRIAN RAMPS, ETC., MAY BE ADJUSTED AS DIRECTED BY THE ENGINEER/INSPECTOR.
5. ALL PAVEMENT MARKINGS WITH THE EXCEPTION OF PARKING STALLS SHALL BE THERMOPLASTIC.
6. STRIPING AND SIGNING SHALL CONFORM WITH THE LATEST EDITION OF THE MANUAL OF UNIFORM TRAFFIC CONTROL DEVICES AND THE FLORIDA DEPARTMENT OF TRANSPORTATION DESIGN STANDARD MANUAL.

1



PAVEMENT MARKINGS AND SIGNAGE PLAN

SCALE: 1" = 30'



Call 811 or www.sunshine811.com two full business days before digging to have utilities located and marked.
Check positive response codes before you dig!

ENGINEER'S CERTIFICATION:

I HEREBY CERTIFY: That this plan was prepared under my direction and to the best of my knowledge and belief complies with the intent of the "MANUAL OF UNIFORM STANDARDS FOR DESIGN, CONSTRUCTION AND MAINTENANCE FOR STREETS, AND HIGHWAYS", as adopted by the State of Florida Legislature, Chapter 72-328 F.S.


CONSULTANT INFO:



VENETIAN PARC WEST K-5 SCHOOL

SOUTHWEST 157th AVENUE and 174th STREET
MIAMI, FL. 33187
MDCPS PROJECT No. 01892600

KEY PLAN

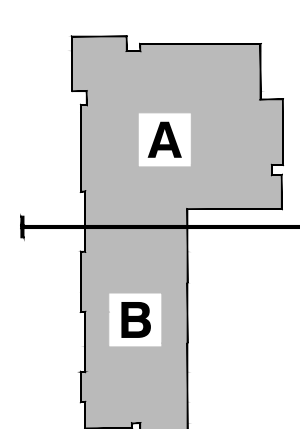

CONSULTANT INFO:

Jorge R. Avila
PE No. 22207

RODRIGUEZ ARCHITECTS INCORPORATED
2121 PONCE DE LEON BLVD. STE. 1010
CORAL GABLES, FL. 33134
TEL: (305) 448-3373
FAX: (305) 448-3374

AAC 001933

REVISIONS:




02.14.20 BCC COMMENTS

DRAWING TITLE:

PAVEMENT MARKINGS & SIGNAGE PLAN

SCALE AS NOTED


ISSUE DATE: 12.16.19
PROJECT NO: 1906
SHEET: C-4

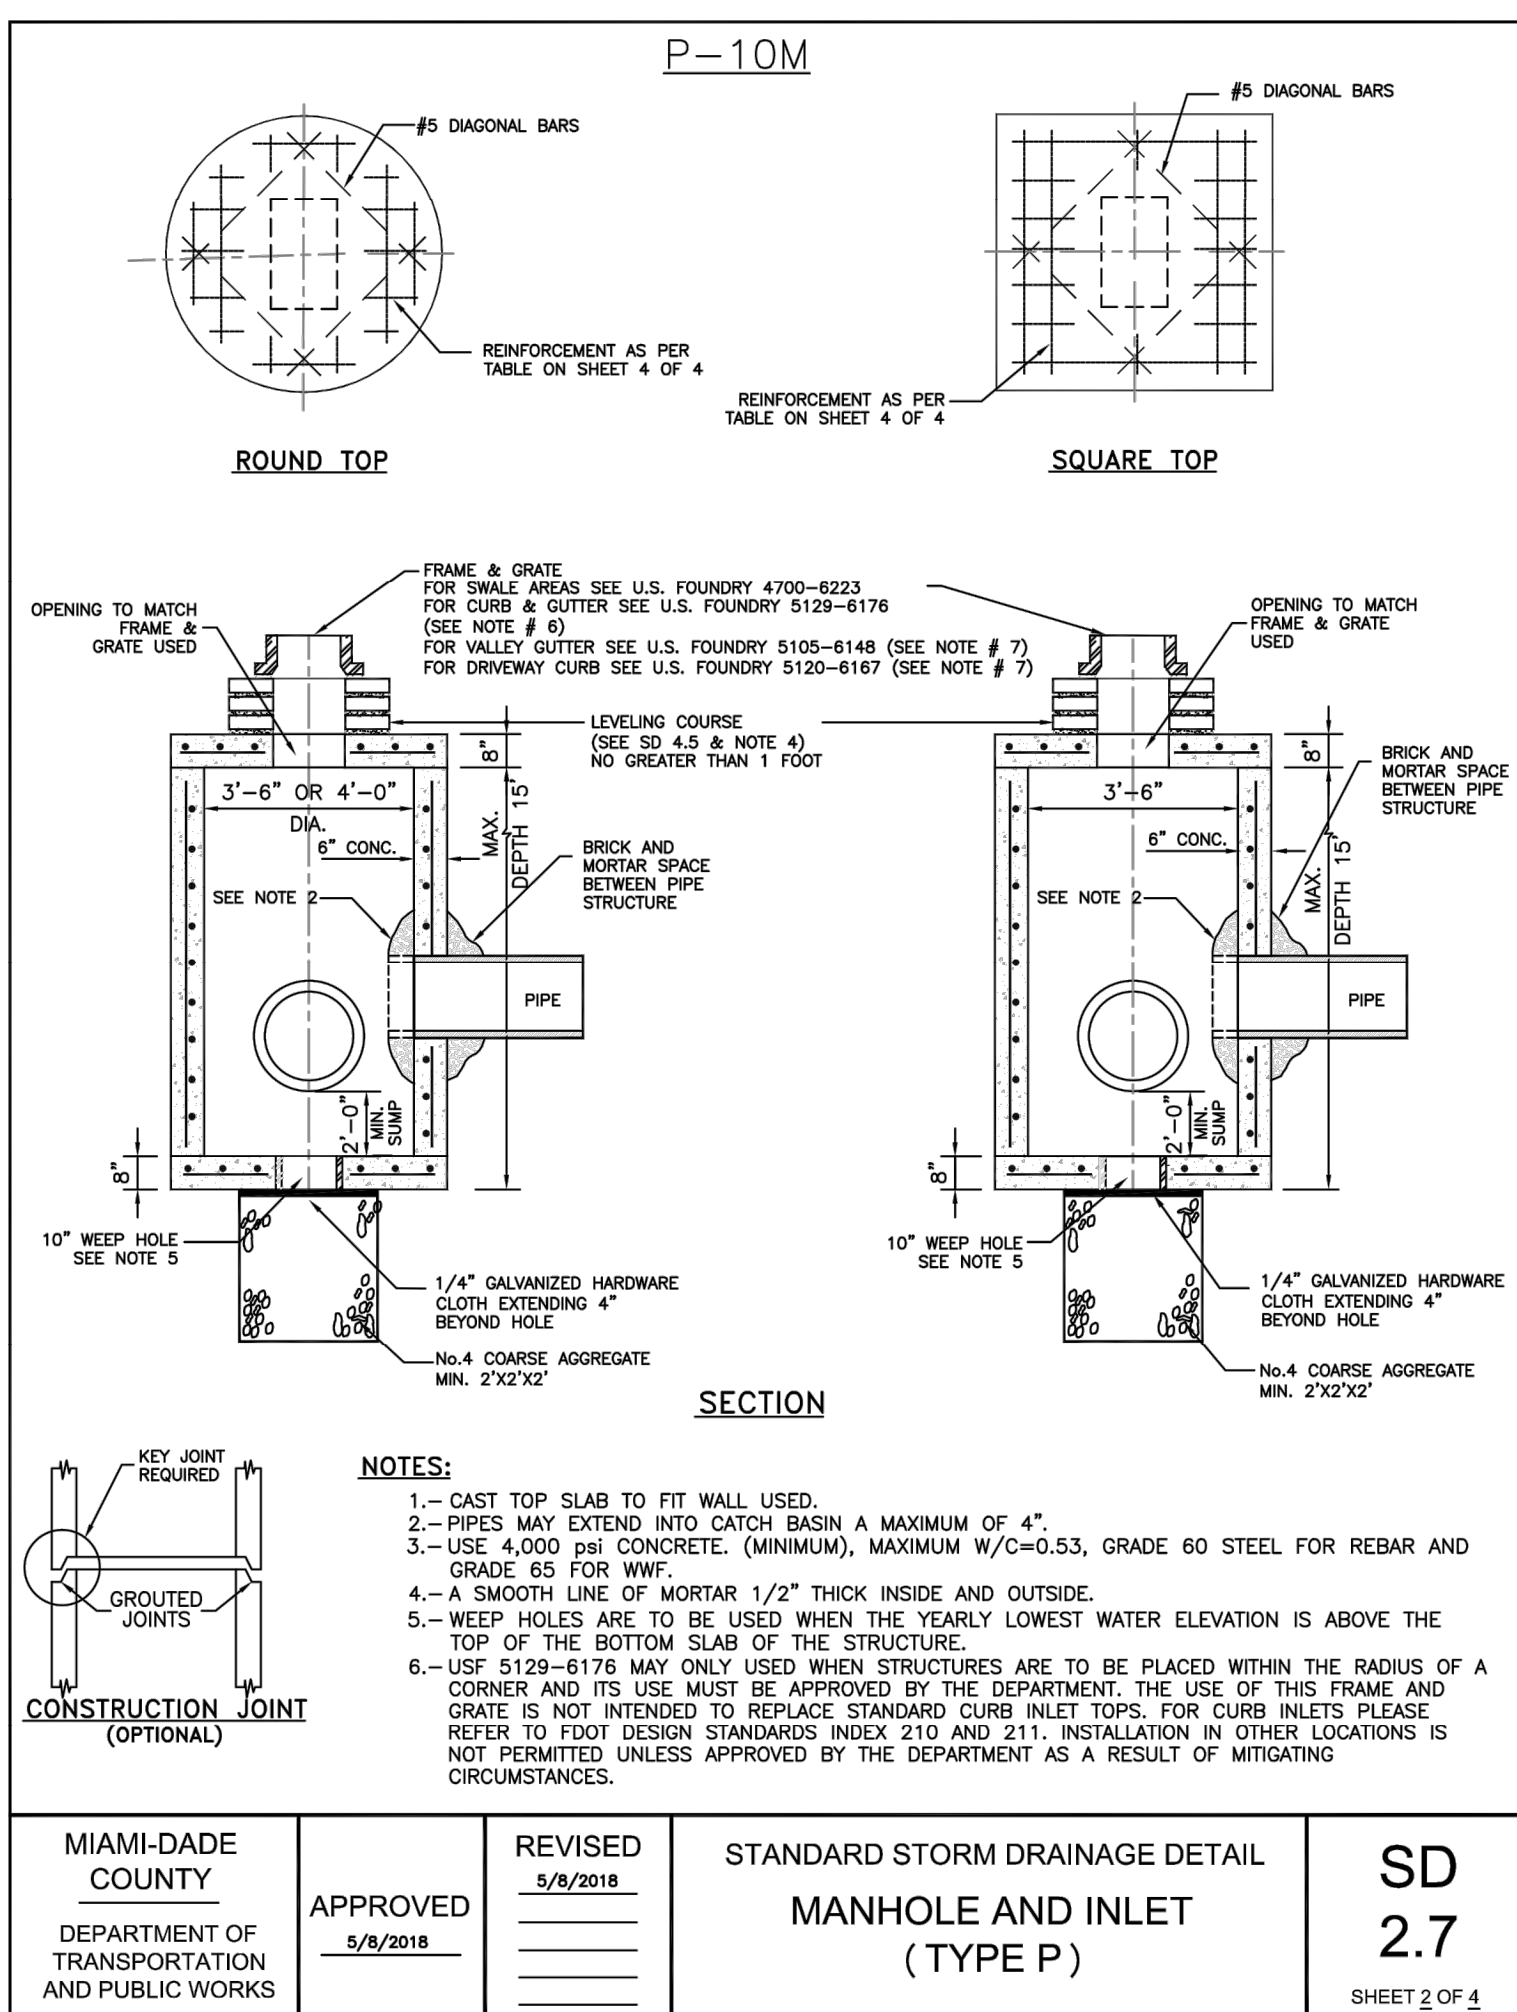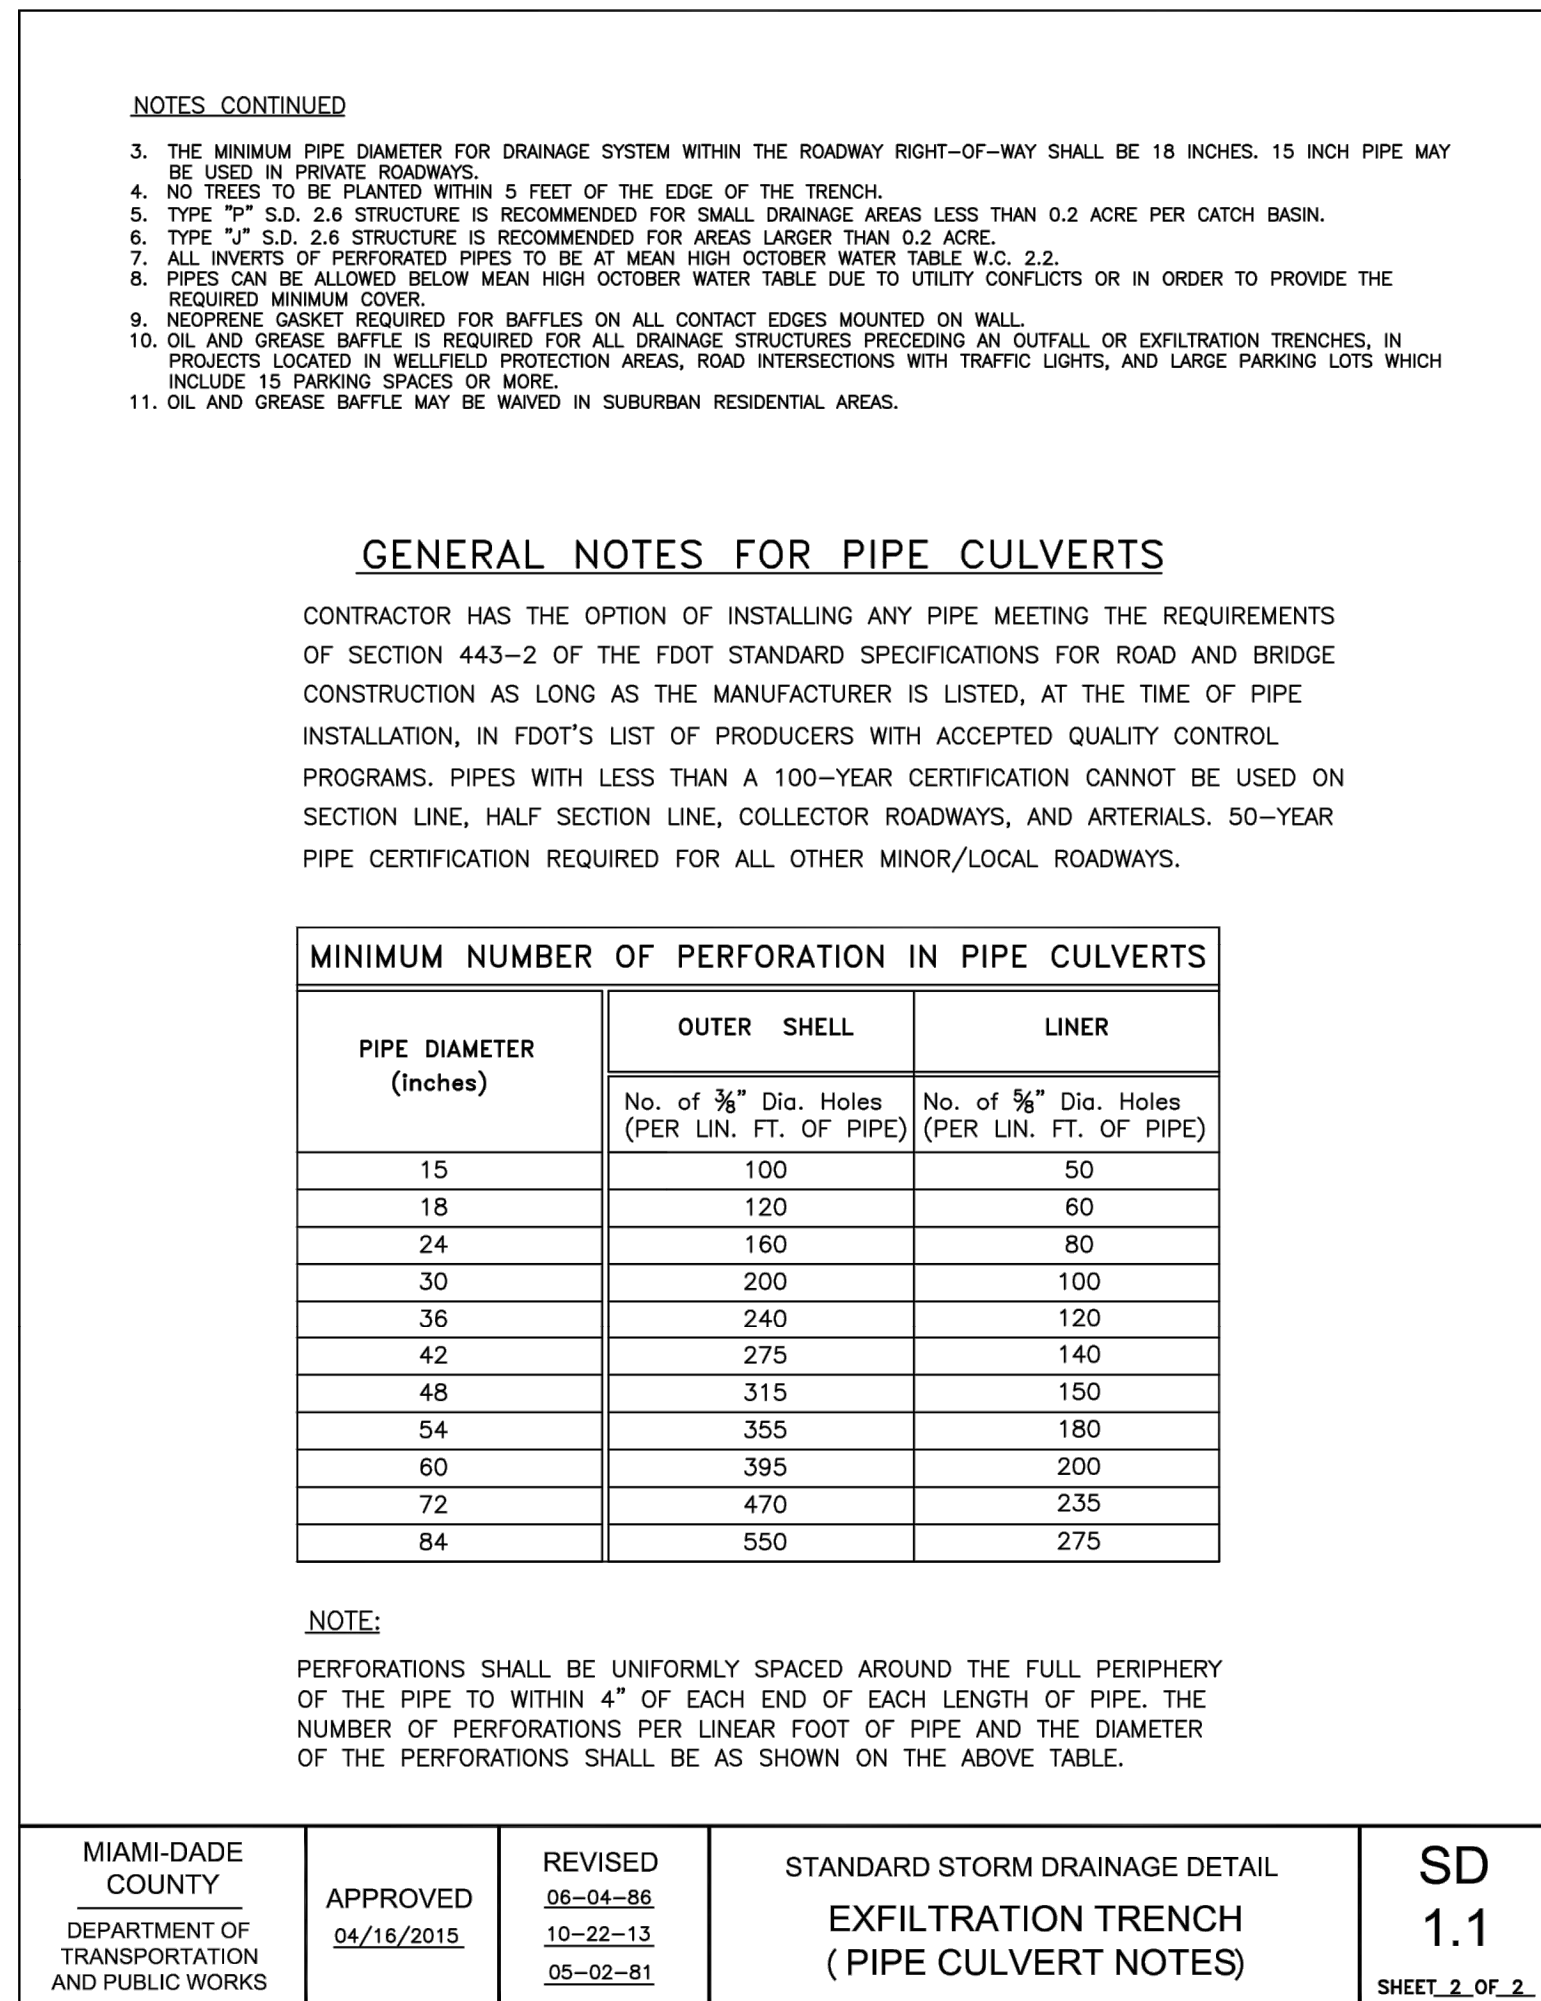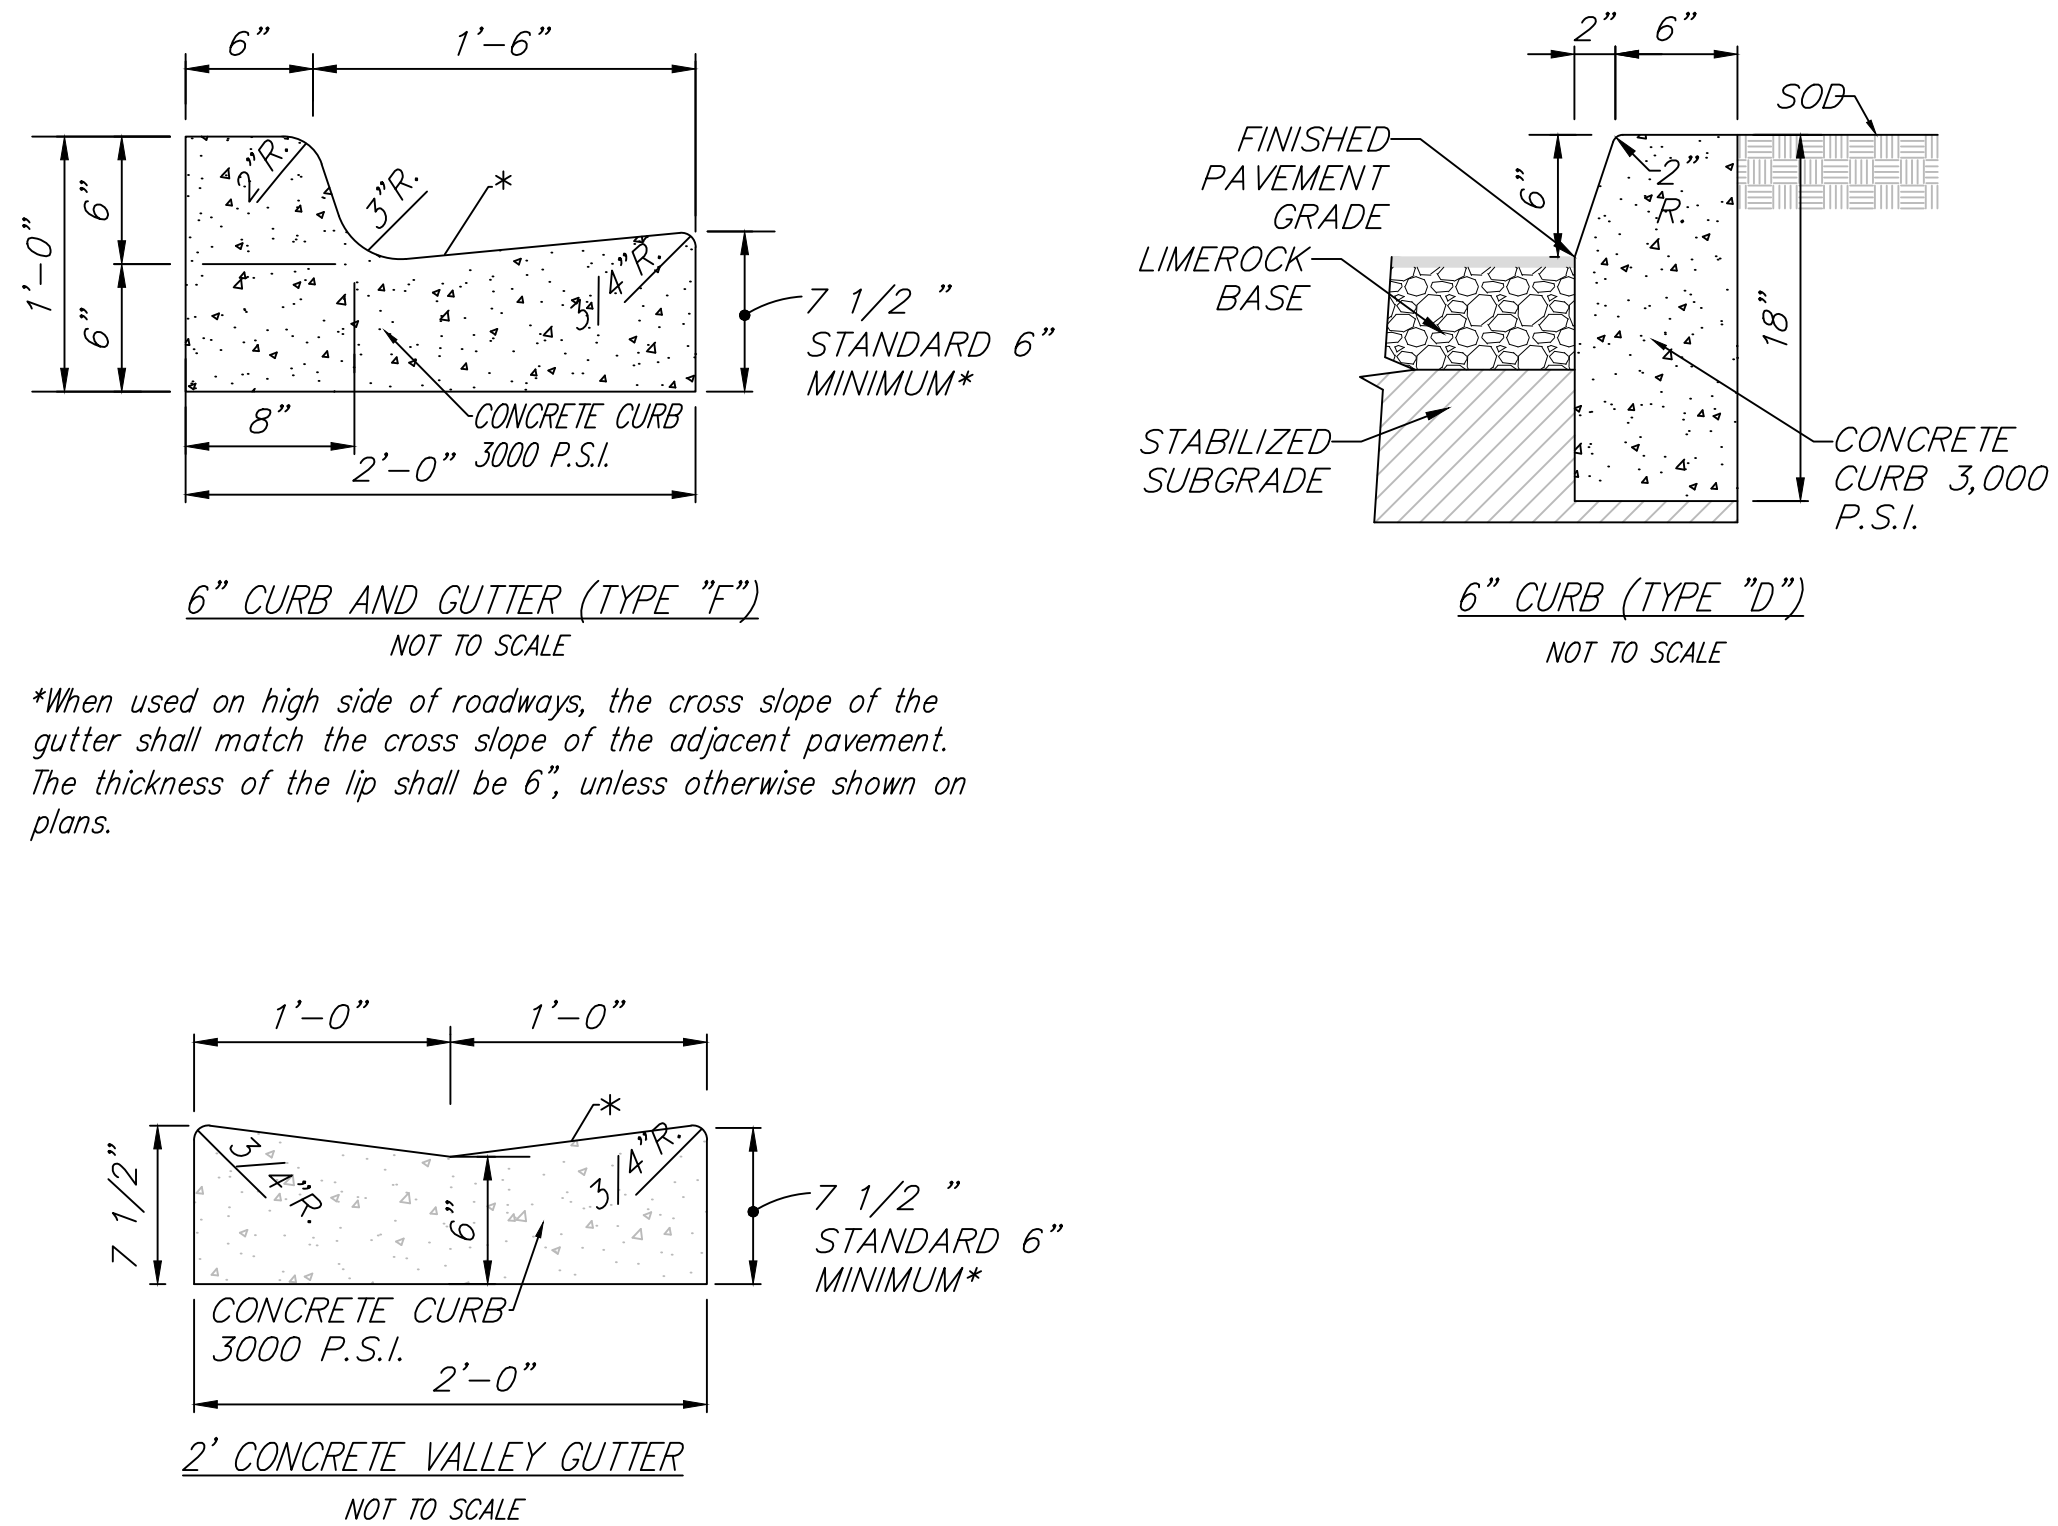

SOUTHWEST 157th AVENUE and 174th STREET
MIAMI, FL. 33187
MDCPS PROJECT No. 01892600


**RODRIGUEZ
ARCHITECTS
INCORPORATED**
2121 PONCE DE LEÓN BLVD. STE. 1010
CORAL GABLES, FL. 33134
TEL: (305) 448-3373
FAX: (305) 448-3374
A A C — 0 0 1 9 3 3

DRAWING TITLE	
PAVING & DRAINAGE DETAILS	
SCALE AS NOTED	
ISSUE DATE: 12.16.19	PROJECT NO. 1906
SHEET:	

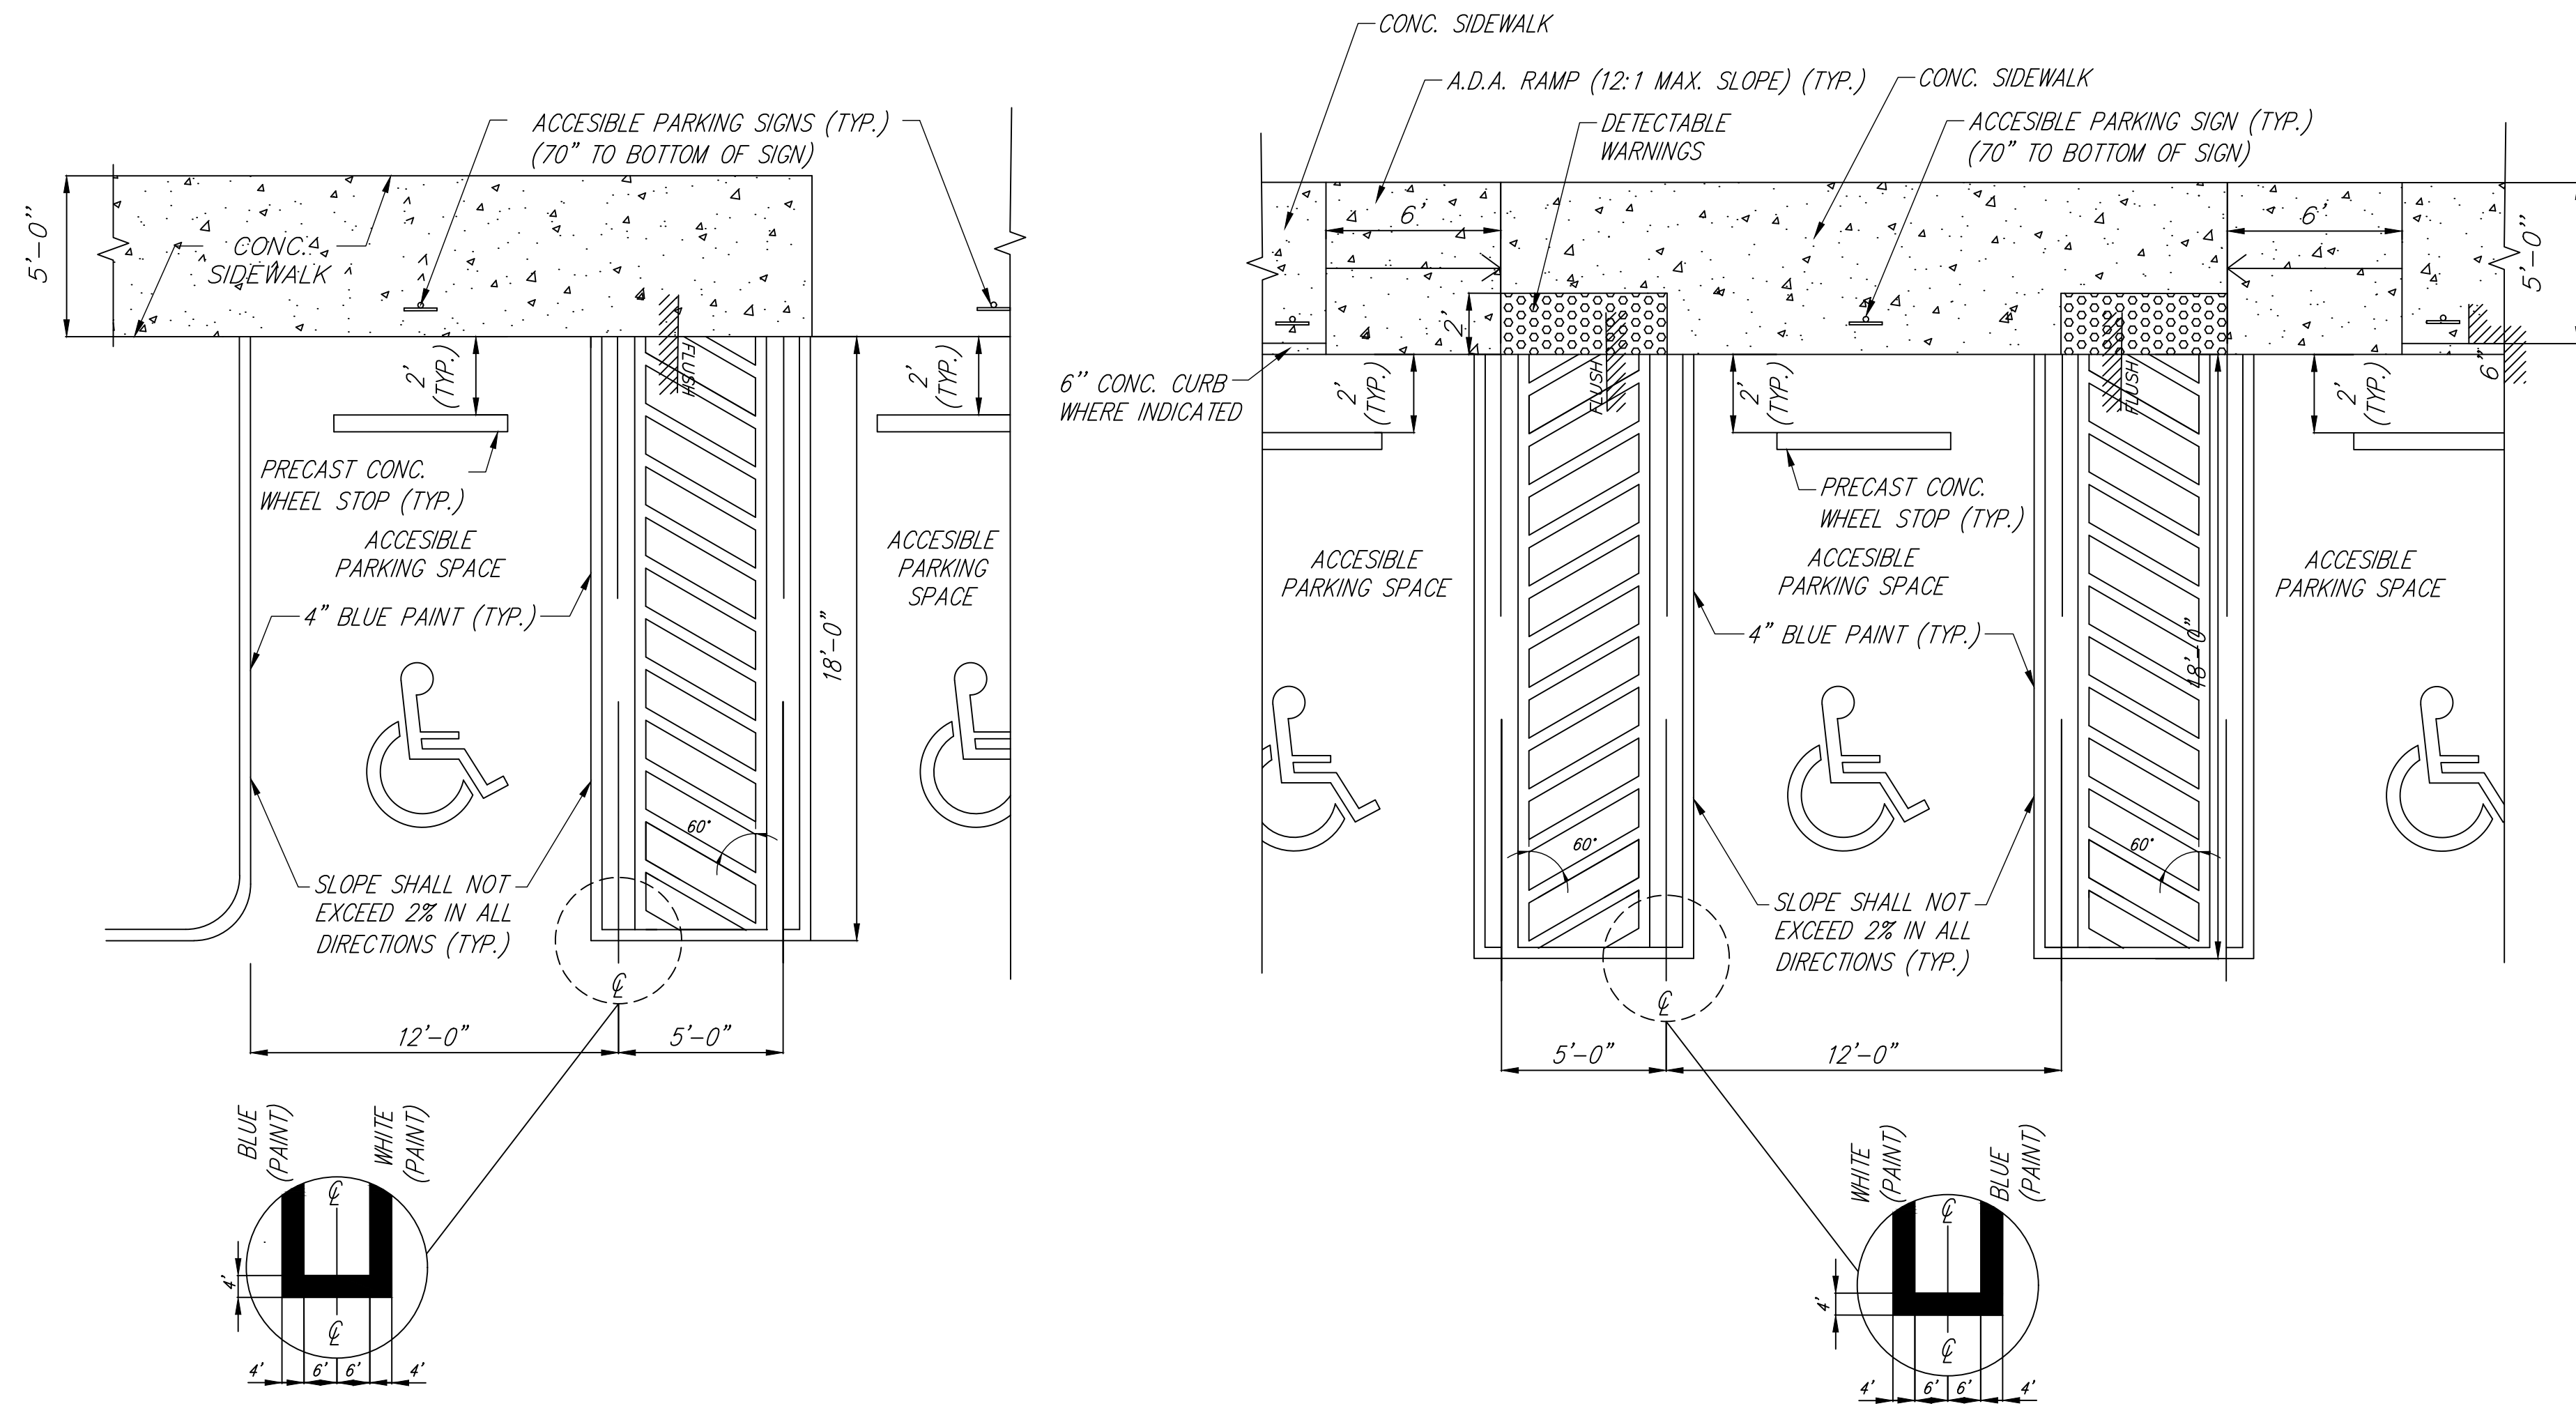

A.D.A. ACCESSIBLE PARKING SPACES AT SOUTH PARKING LOT

A.D.A. ACCESSIBLE PARKING SPACES AT CENTRAL PARKING LOT

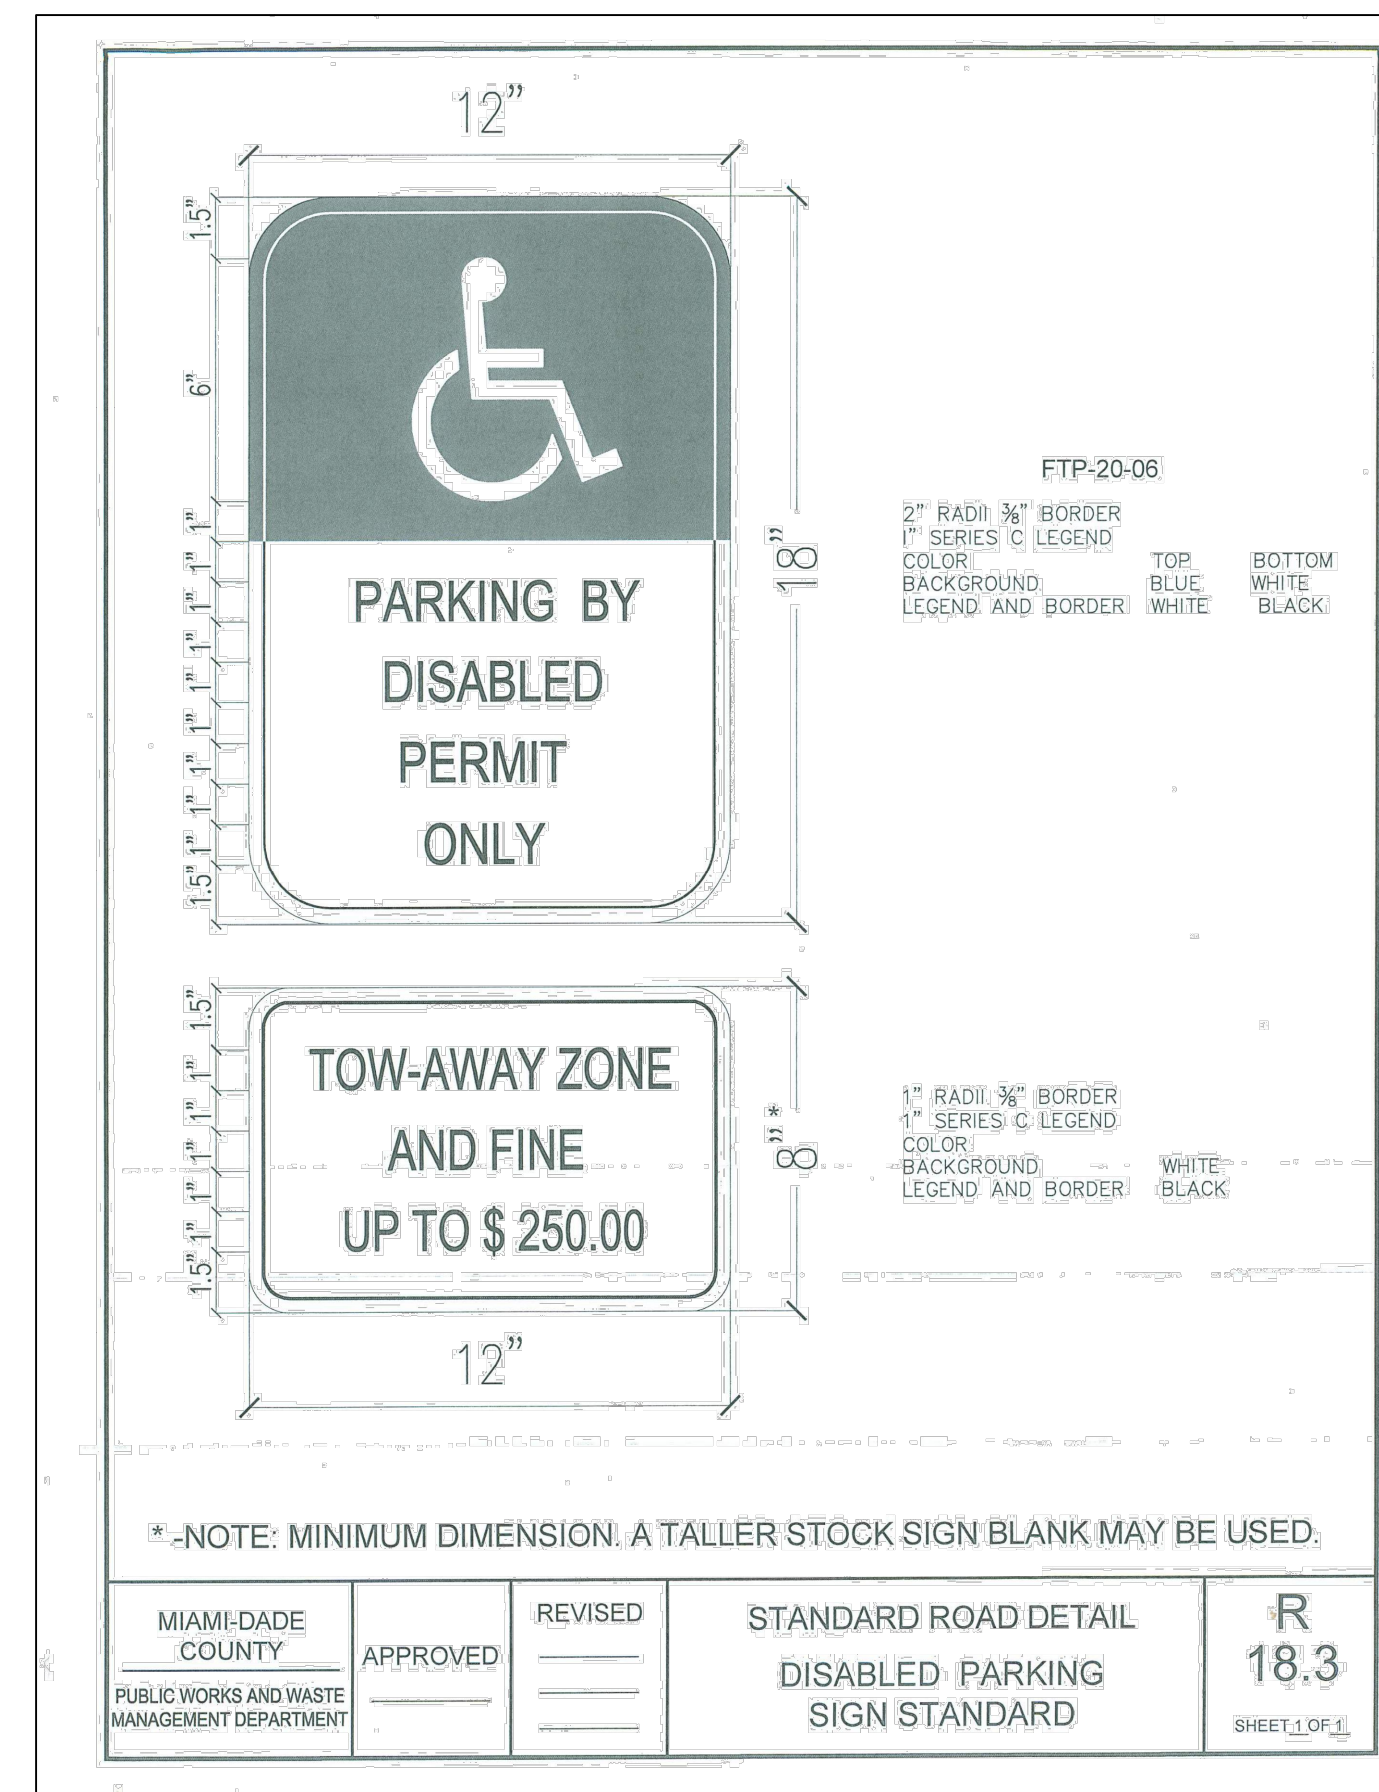

ACCESSIBLE PARKING SPACE SIGN DETAIL
NOT TO SCALE

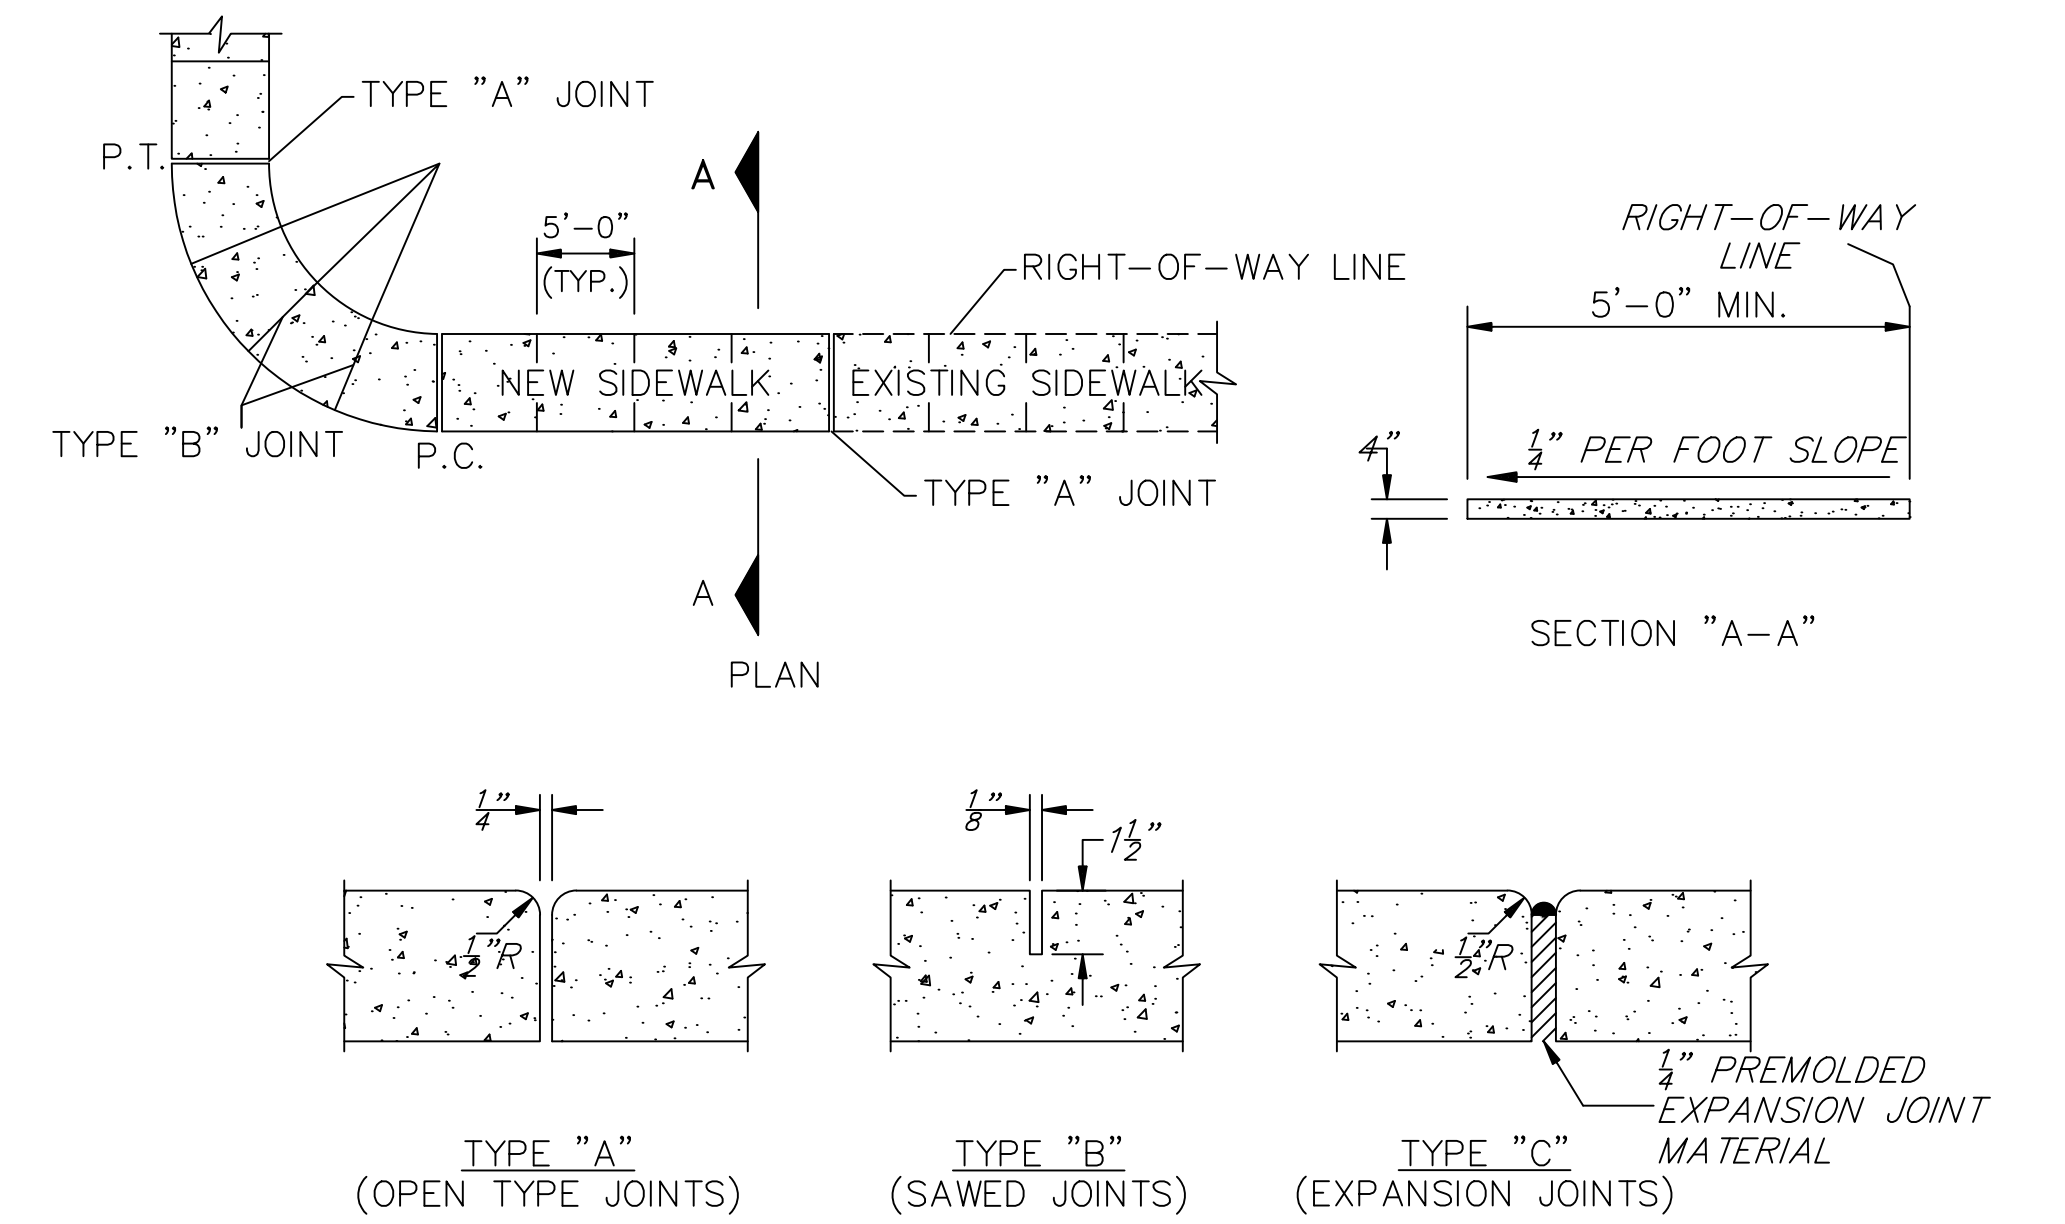



TABLE OF SIDEWALK JOINTS

TYPE	LOCATIONS
"A"	AND P.T. OF CURVES. JUNCTION OF EXISTING AND NEW SIDEWALKS
"B"	5'-0" CENTER TO CENTER ON SIDEWALKS
"C"	*WHERE SIDEWALK ABUTS CONCRETE CURBS, DRIVEWAYS, AND SIMILAR STRUCTURES


TABLE OF SIDEWALK THICKNESS - "T"

LOCATIONS	"T"
NON-VEHICULAR AREAS	4"
DRIVEWAYS	6"


- NOTES:
- SUBGRADE COMPACTED TO 95% DENSITY AASHTO T-99.

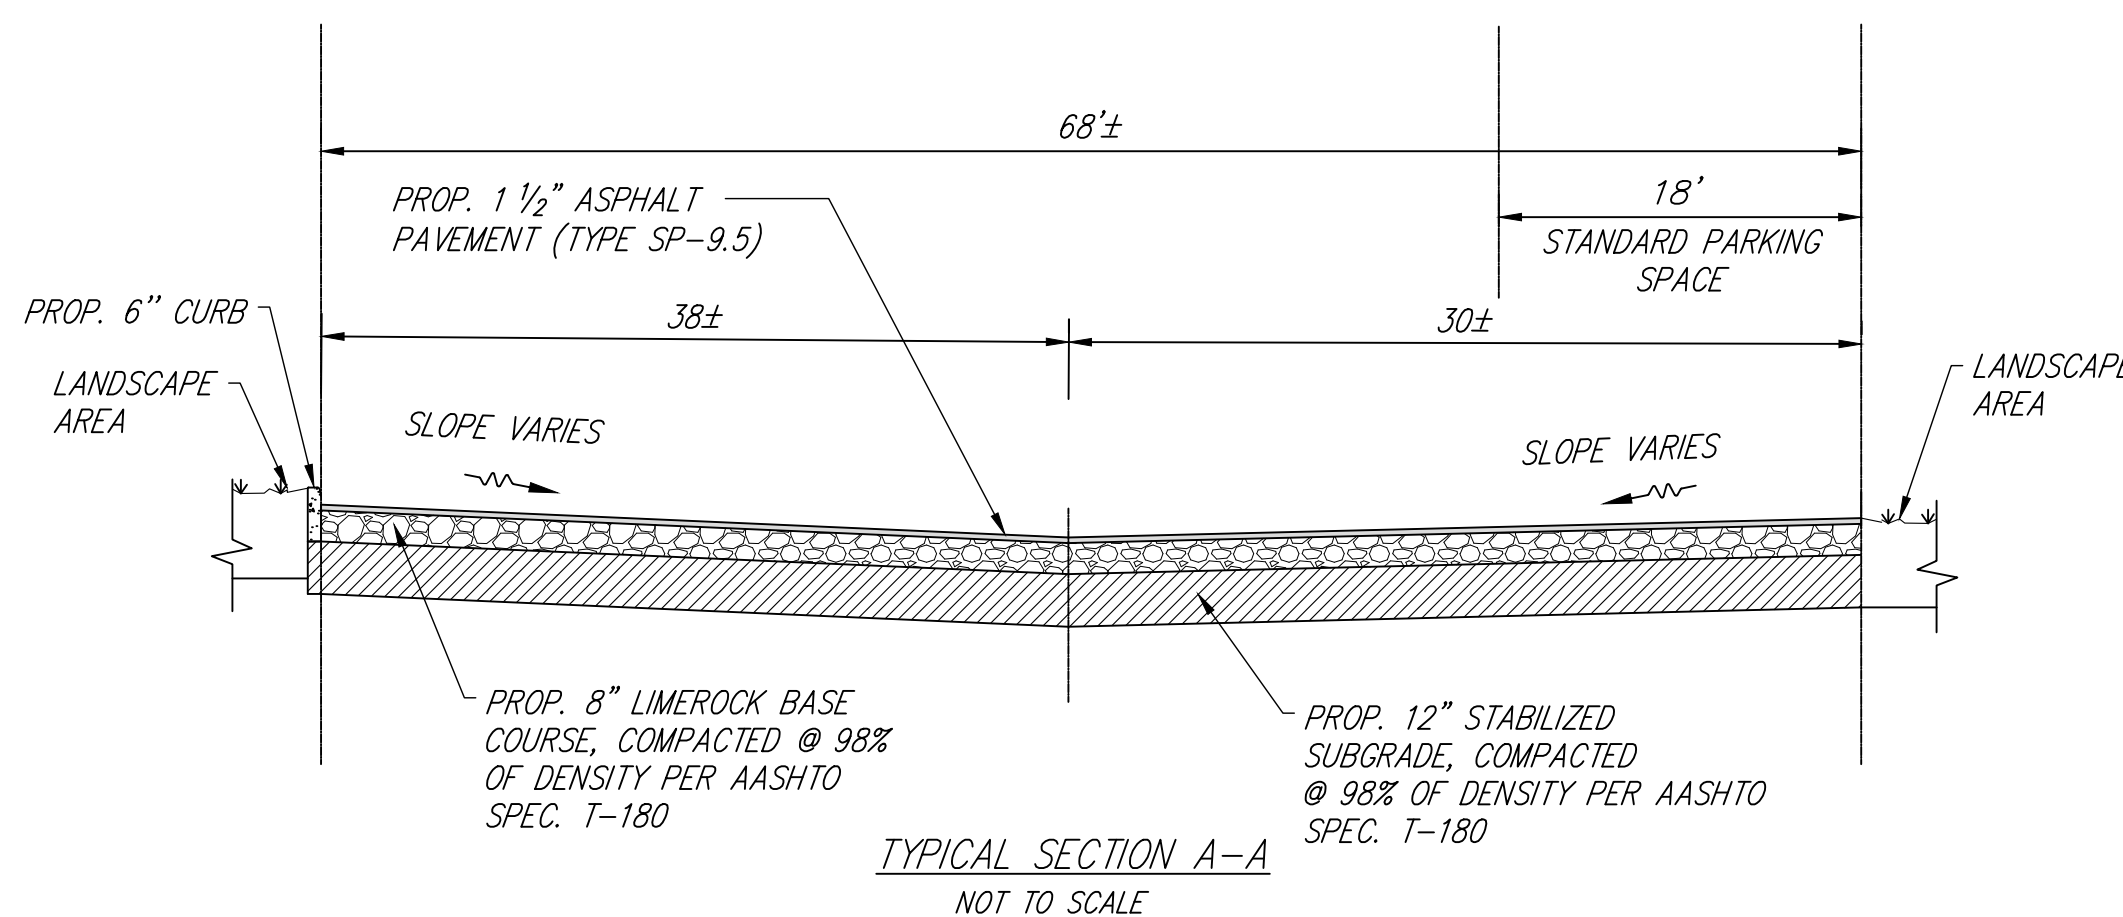


TYPICAL SECTION A-A
NOT TO SCALE

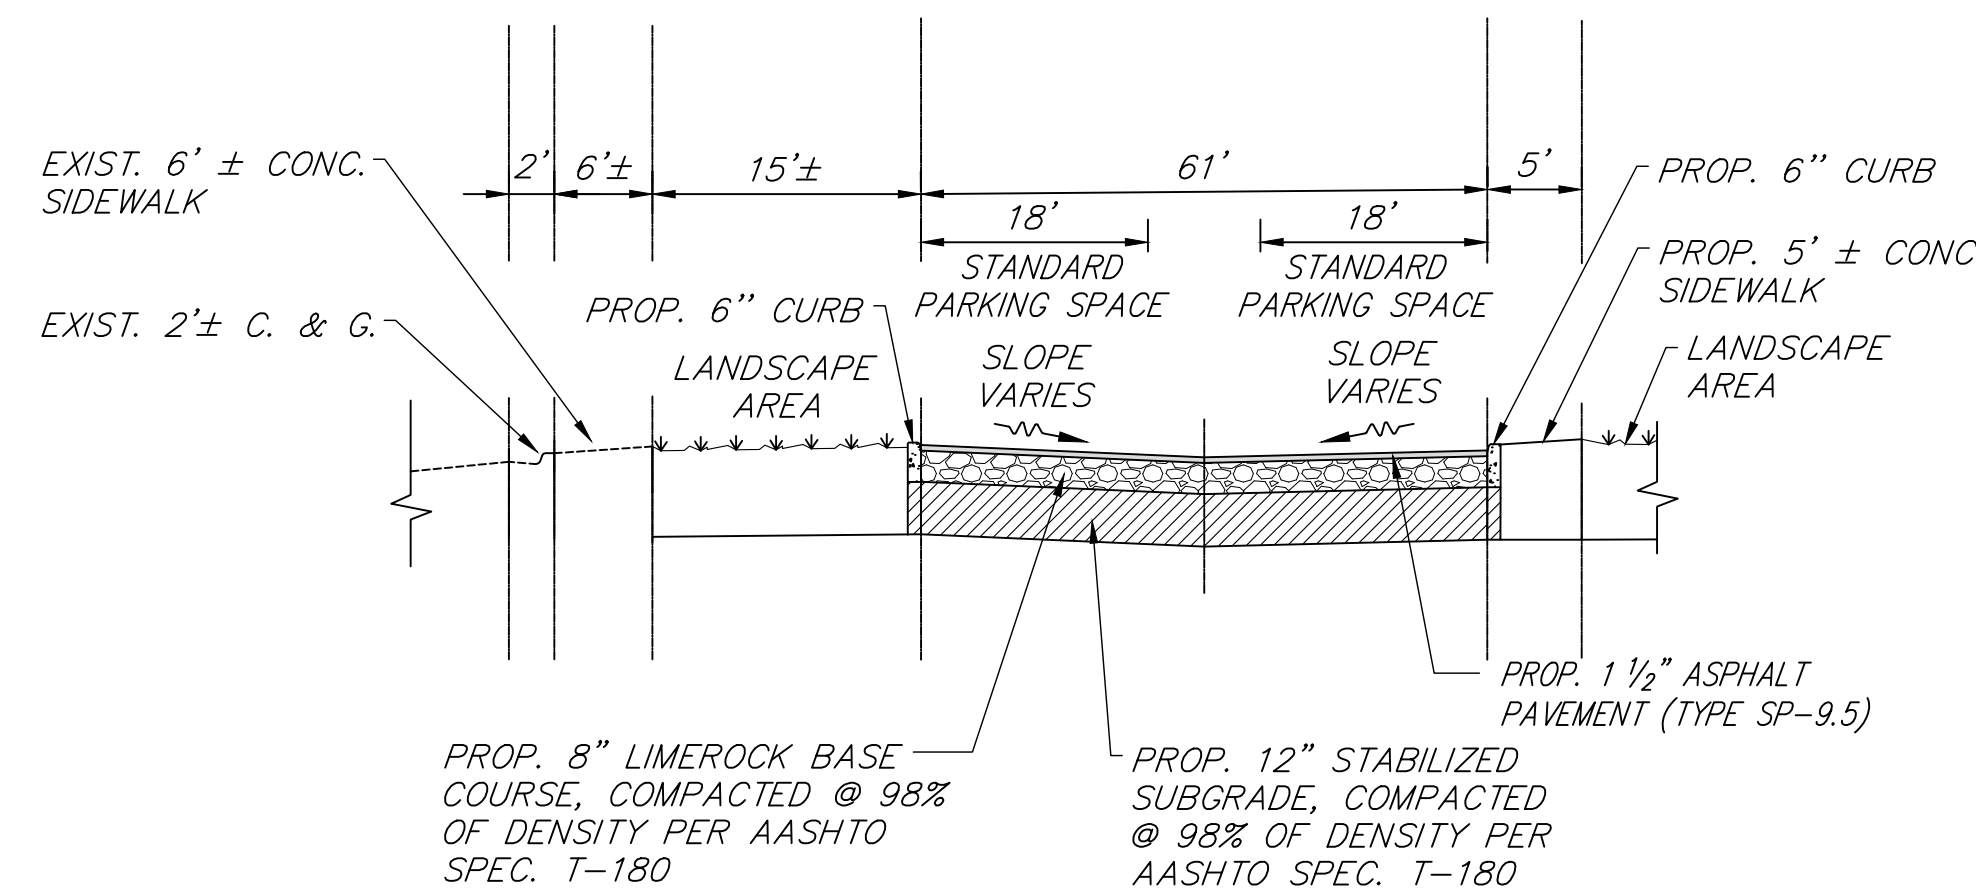


TYPICAL SECTION C-C
NOT TO SCALE

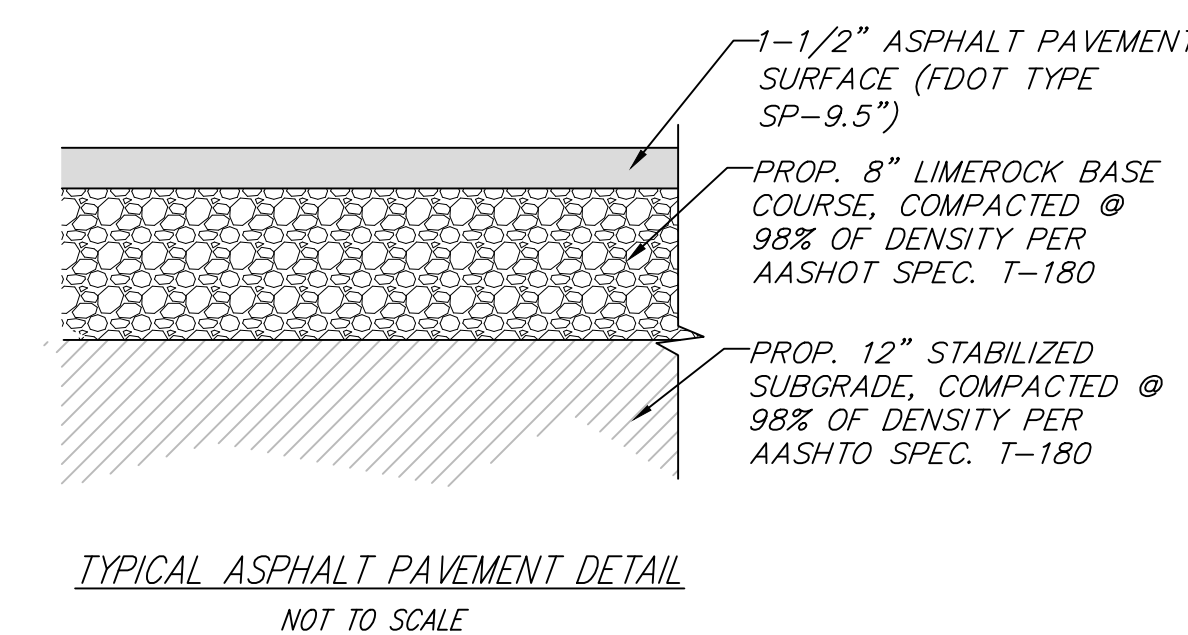


TYPICAL ASPHALT PAVEMENT DETAIL
NOT TO SCALE

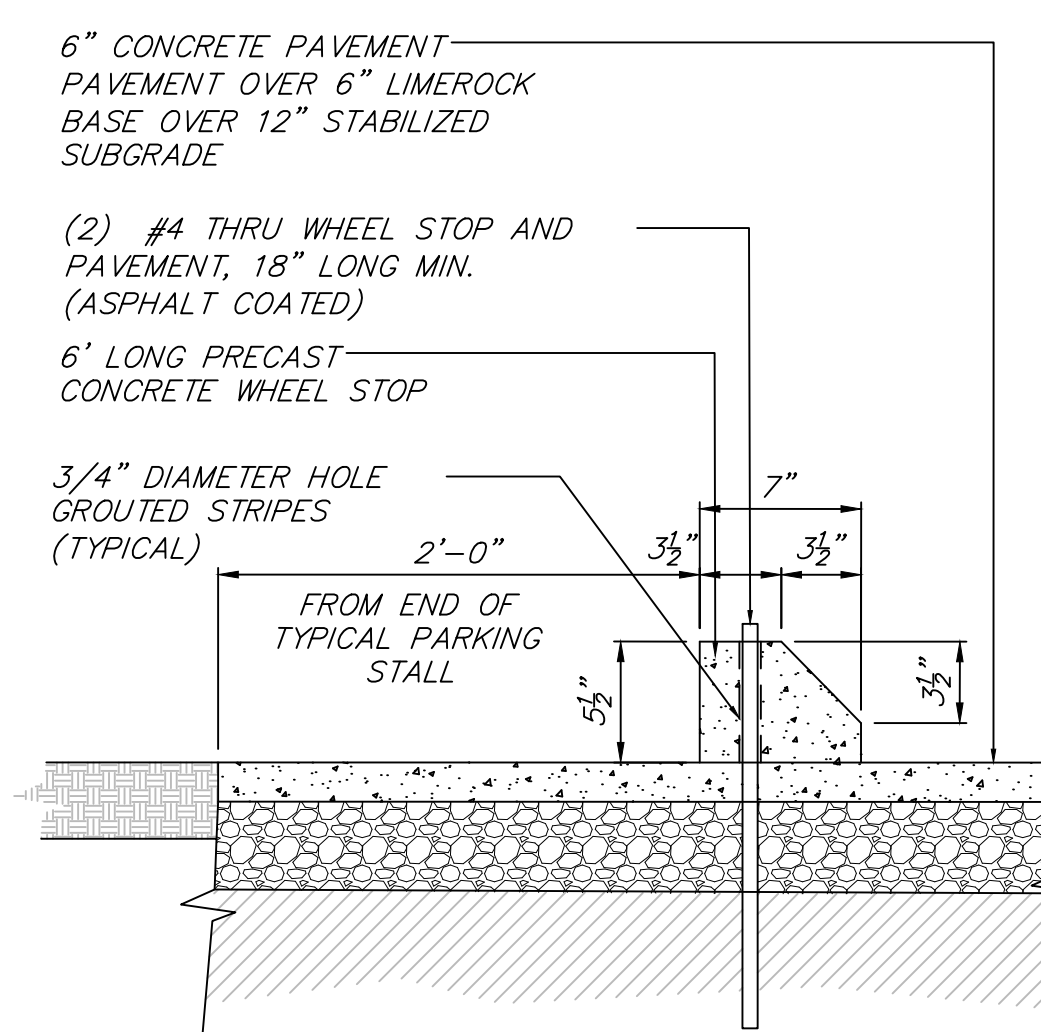


TYPICAL WHEEL STOP DETAIL
NOT TO SCALE

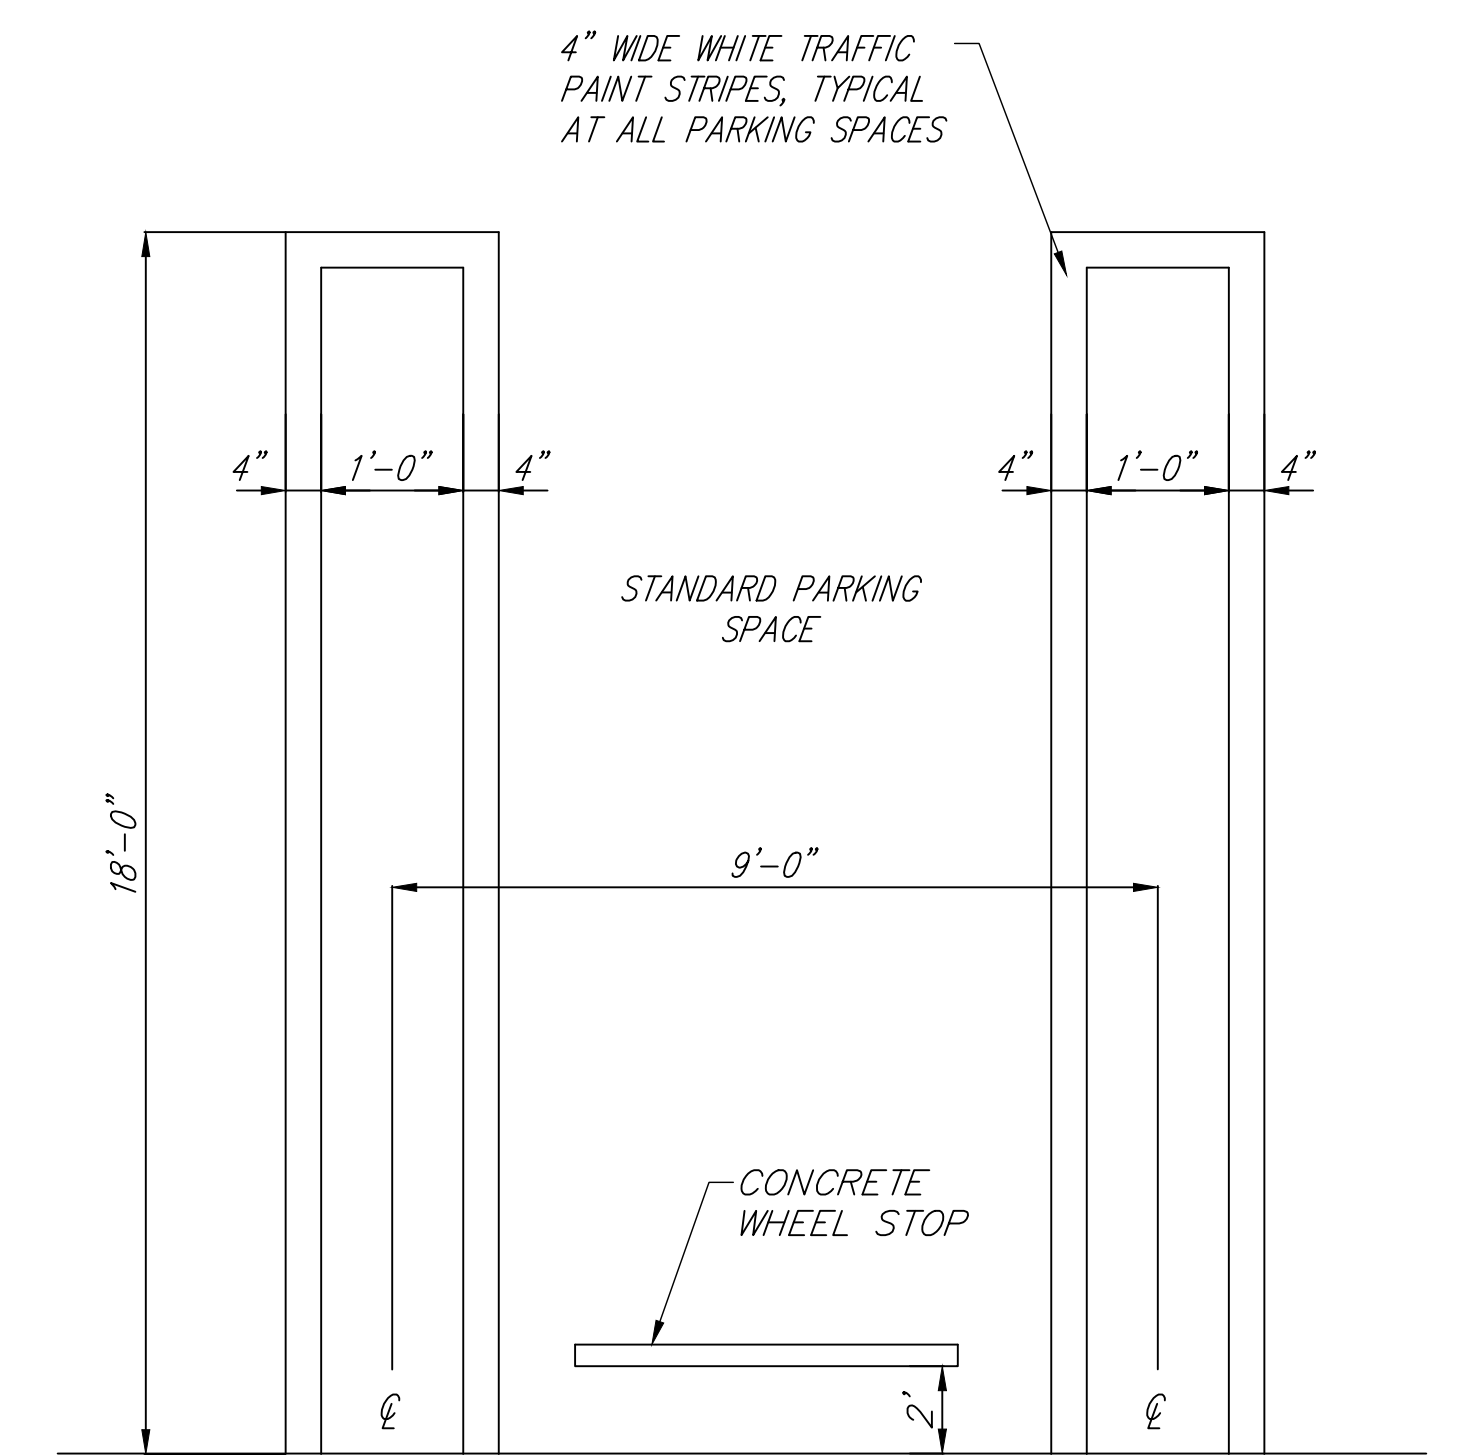

STANDARD PARKING STALL DETAIL
NOT TO SCALE

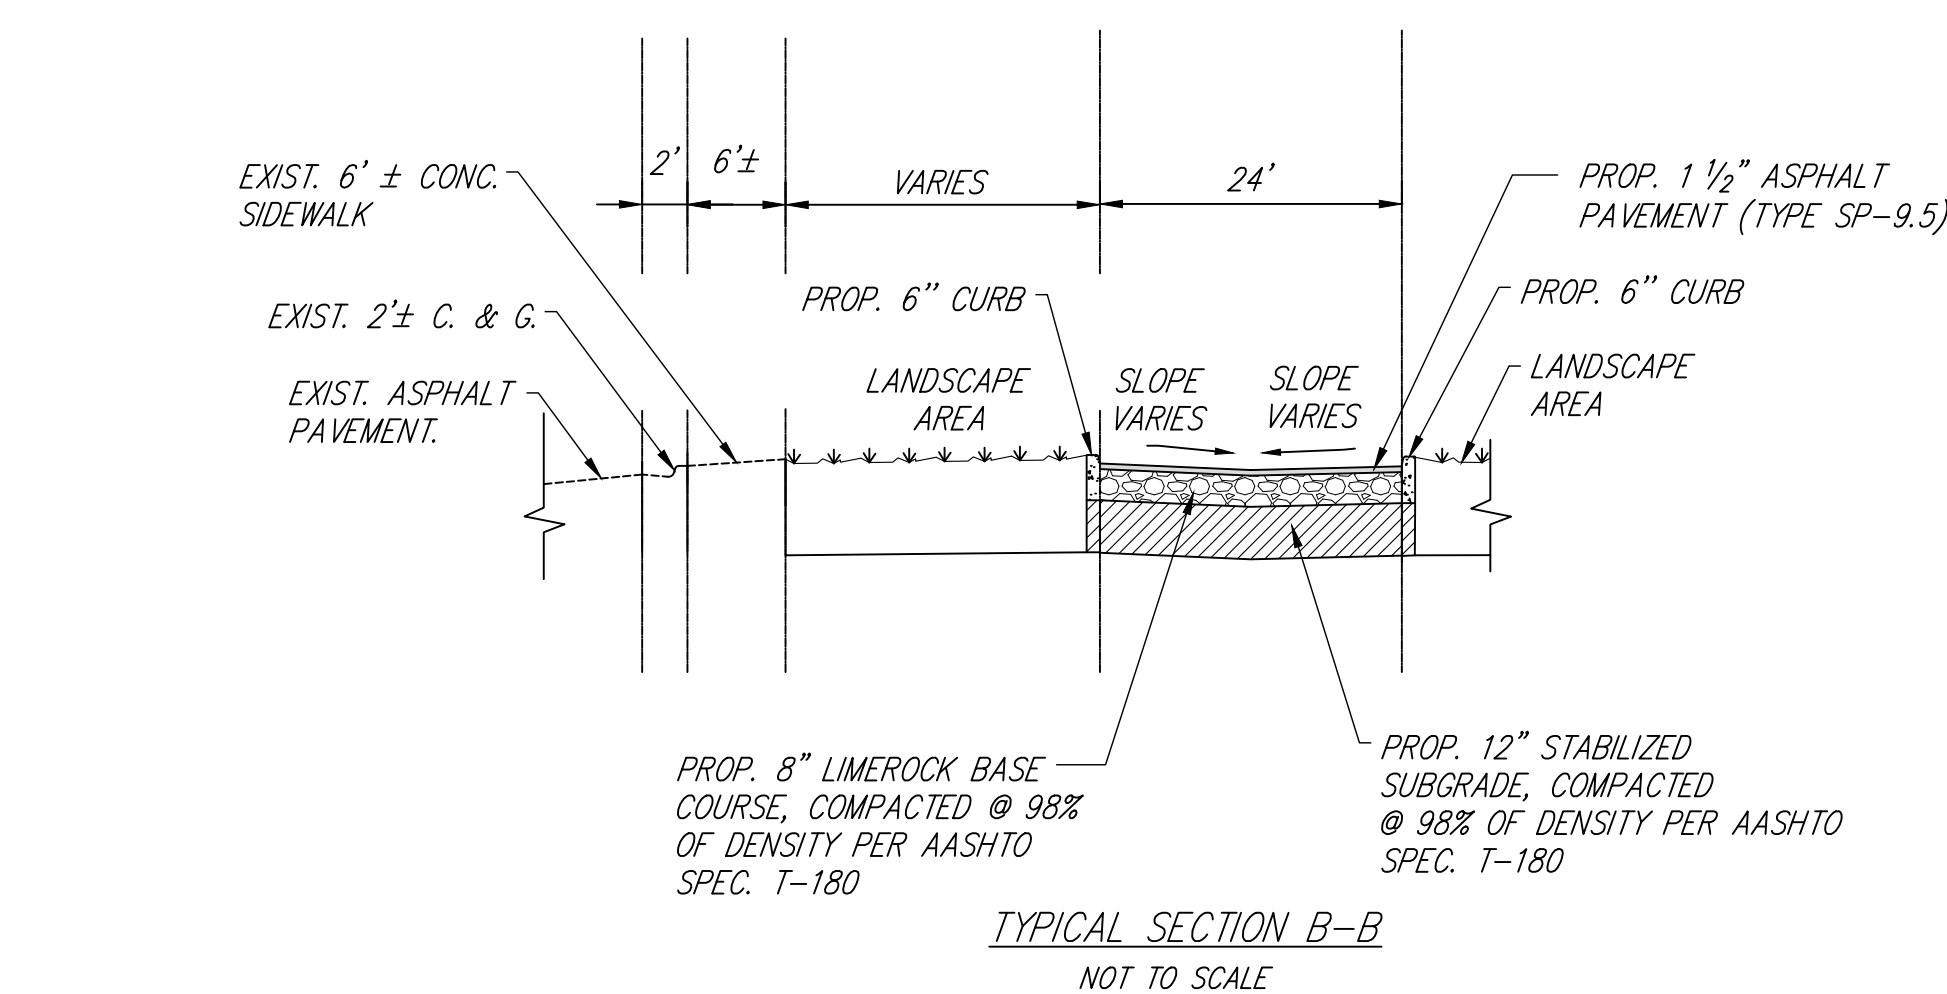

TYPICAL SECTION B-B
NOT TO SCALE

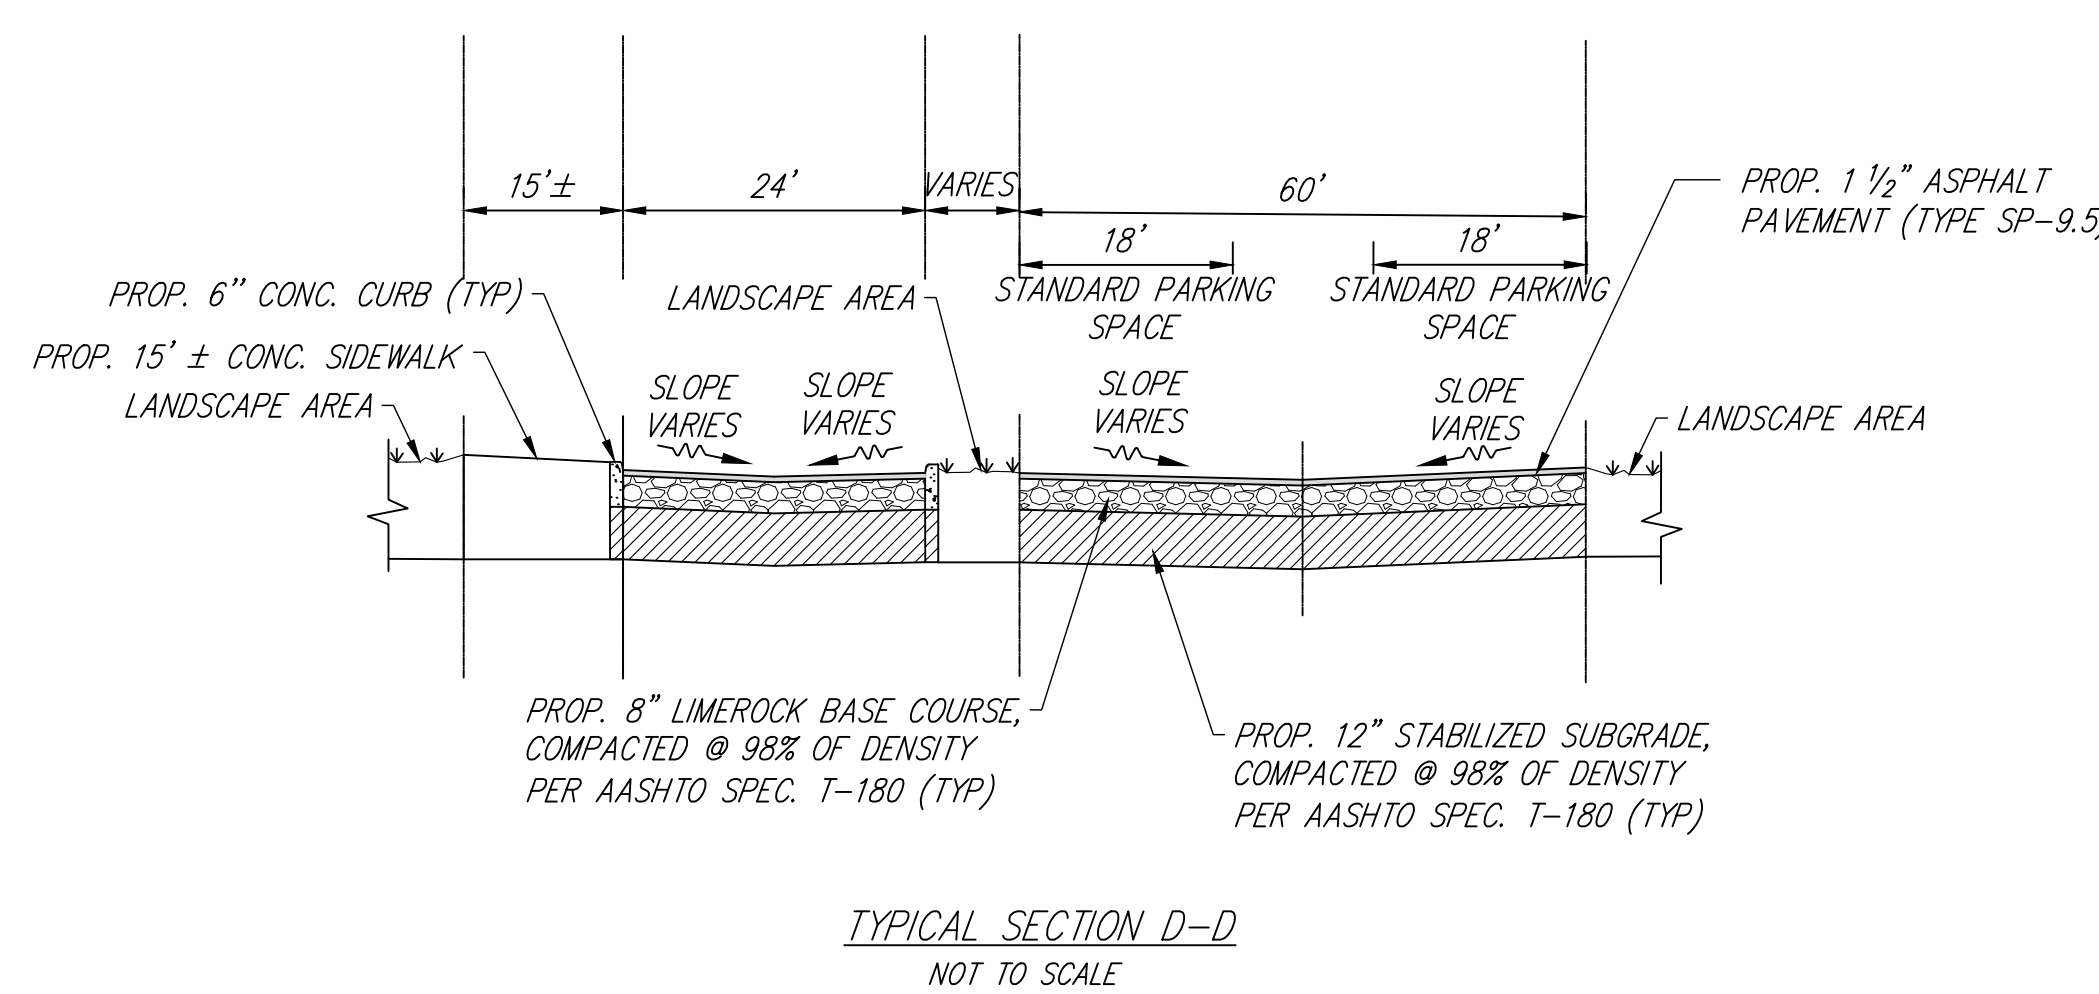

TYPICAL SECTION D-D
NOT TO SCALE


PAVING AND DRAINAGE DETAILS

NOT TO SCALE

VENETIAN PARC WEST K-5 SCHOOL

SOUTHWEST 157th AVENUE AND 174th STREET
MIAMI, FL. 33187
MDCPS PROJECT No. 01892600

KEY PLAN

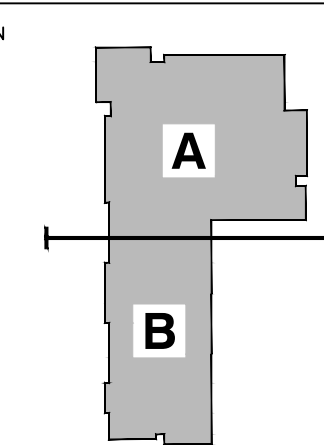

CONSULTANT INFO:

Jorge R. Avila
PE No. 22207

RODRIGUEZ ARCHITECTS INCORPORATED
2121 PONCE DE LEON BLVD. STE. 1010
CORAL GABLES, FL. 33134
TEL: (305) 448-3373
FAX: (305) 448-3374
A A C — 0 0 1 9 3 3



REVISIONS:


02.14.20	BCC COMMENTS
----------	--------------

DRAWING TITLE:

PAVING & DRAINAGE DETAILS	
ISSUE DATE:	PROJECT NO.
12.16.19	1906
SHEET:	C-6

CHECKED BY:	DRAWN BY:
N.V.	C.O.

CONSULTANT INFO:


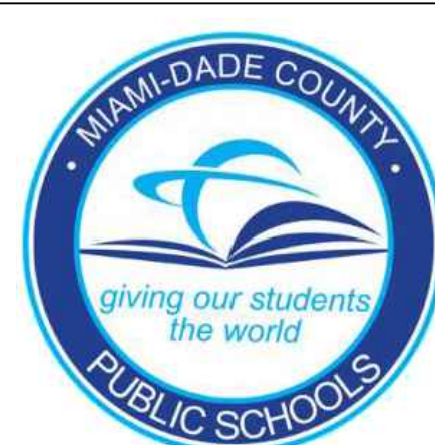


ENGINEER'S CERTIFICATION:

I HEREBY CERTIFY: That this plan was prepared under my direction and to the best of my knowledge and belief complies with the intent of the "MANUAL OF UNIFORM STANDARDS FOR DESIGN, CONSTRUCTION AND MAINTENANCE FOR STREETS, AND HIGHWAYS", as adopted by the State of Florida Legislature, Chapter 72-328 F.S.

GENERAL NOTES:

1. SILT FENCES SHALL BE PROVIDED AS SHOWN AROUND THE PROPERTY TO PREVENT CONSTRUCTION DEBRIS FROM WASHING OFF-SITE.
2. FILTER FABRIC SHALL BE INSTALLED AT ALL NEW AND EXISTING INLETS DURING CONSTRUCTION.
3. FOR ADDITIONAL STRENGTH FILTER FABRIC MATERIAL CAN BE ATTACHED TO A 6" (MAX.) MESH WIRE SCREEN WHICH HAS BEEN FASTENED TO THE POSTS.
4. THE FABRIC MATERIAL AND THE WIRE MESH SHALL NOT EXTEND MORE THAN 36" (90 CM) ABOVE THE ORIGINAL GROUND SURFACE.
5. SILT FENCES AND FILTER BARRIERS SHALL BE INSPECTED IMMEDIATELY AFTER EACH RAINFALL AND AT LEAST DAILY DURING PROLONGED RAINFALL. ANY REQUIRED REPAIRS SHALL BE MADE IMMEDIATELY.
6. THE CONTRACTOR IS RESPONSIBLE FOR REMOVING THE TEMPORARY EROSION AND SEDIMENT CONTROL DEVICES AFTER COMPLETION OF CONSTRUCTION AND ONLY IN THE AREAS WHICH HAVE BEEN STABILIZED.
7. CONTRACTOR SHALL INSURE THAT ALL DRAINAGE STRUCTURES, PIPES, ETC. ARE CLEANED OUT COMPLETELY AND ARE WORKING PROPERLY AT THE TIME OF ACCEPTANCE.
8. FILTER FABRIC SHALL BE LAID OUT UNDER THE GRATE OF EACH INLET, EXTENDING A MINIMUM OF ONE (1') FOOT BEYOND EACH SIDE OF THE INLET STRUCTURE. IF MORE THAN ONE STRIP OF MESH IS NECESSARY, THE STRIPS SHALL BE OVERLAPPED A MINIMUM OF ONE (1') FOOT.
9. IF THE INLET FILTER BECOMES CLOGGED WITH SEDIMENT, SO THAT IT NO LONGER ADEQUATELY PERFORMS ITS FUNCTION, THE FILTER MUST BE REMOVED AND REPLACED.
10. ALL BMP'S TO BE INSPECTED AT LEAST WEEKLY.
11. FOR EXISTING TREES TO REMAIN, TO BE REMOVED AND TREE PROTECTION METHOD, SEE ARCHITECTURAL/LANDSCAPING PLANS.
12. CONTRACTOR TO PROVIDE WASTE & MATERIAL STORAGE AREAS AND CONCRETE WASHOUT AREA.
13. THE CONTRACTOR SHALL BE REQUIRED TO CONDUCT DAILY VISUAL INSPECTION OF ALL TEMPORARY AND PERMANENT EROSION CONTROL MEASURES ALONG THE PROJECT. THE CONTRACTOR SHALL MAINTAIN, REPAIR AND/OR REPLACE THESE ITEMS AS NECESSARY.
14. THE CONTRACTOR SHALL HIRE A PROFESSIONAL CIVIL ENGINEER REGISTERED IN THE STATE OF FLORIDA AT THE CONTRACTOR'S EXPENSE, AS AN INSPECTOR TO REVIEW ALL THE PROJECT'S TEMPORARY AND PERMANENT EROSION CONTROL MEASURES AT LEAST ONCE EVERY SEVEN (7) CALENDAR DAYS AND/OR WITHIN 24 HOURS OF THE END OF A STORM THAT IS 0.5 INCHES OR GREATER. A WRITTEN INSPECTION REPORT IS REQUIRED EVERY SEVEN (7) CALENDAR DAYS OR WITHIN 24 HOURS OF THE END OF A STORM THAT GENERATES 0.5 INCHES OR MORE OF RAIN.

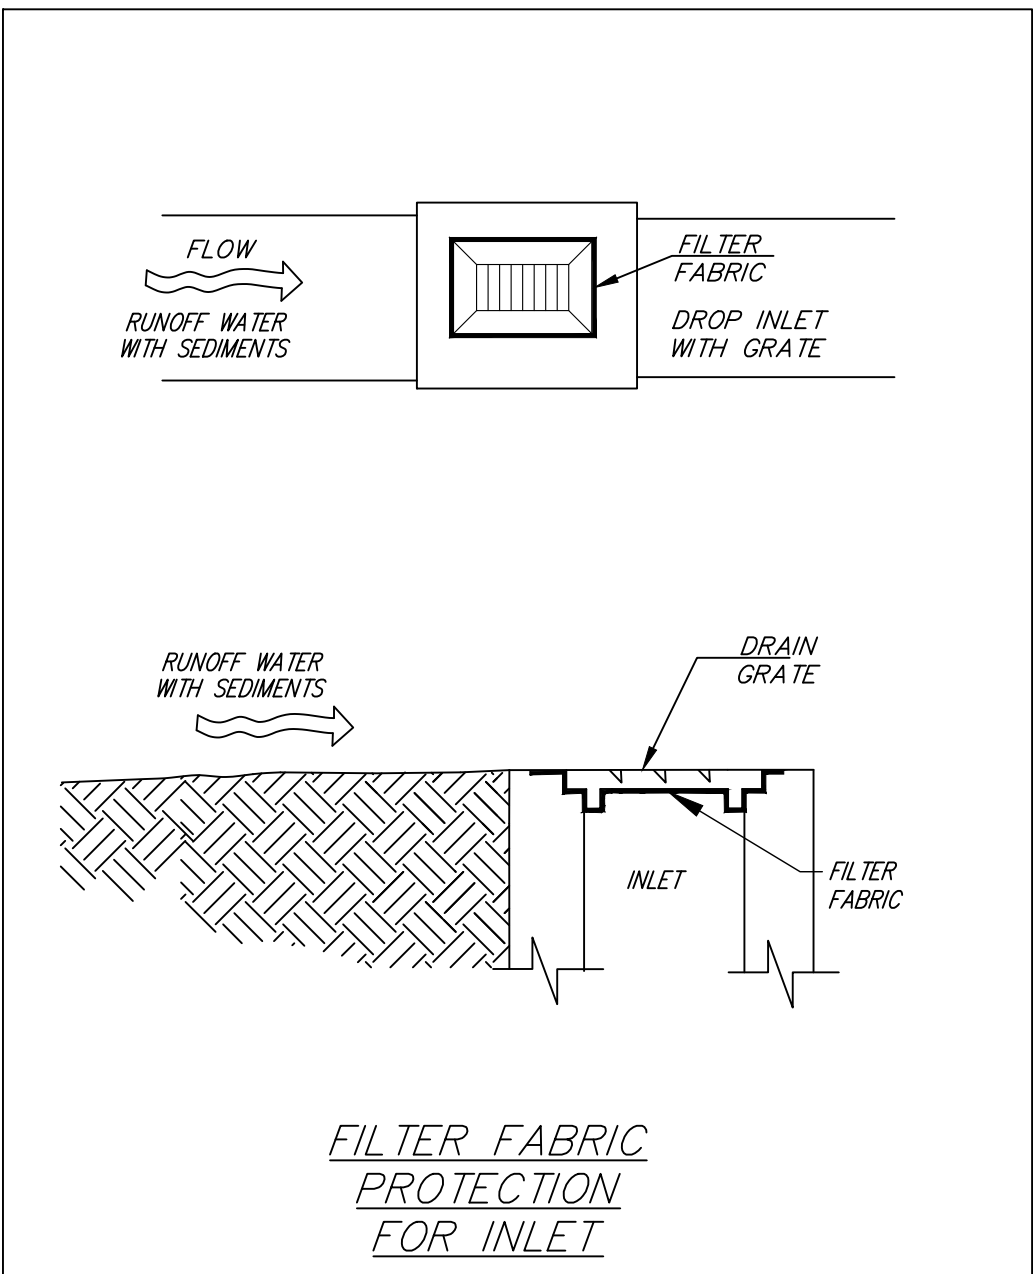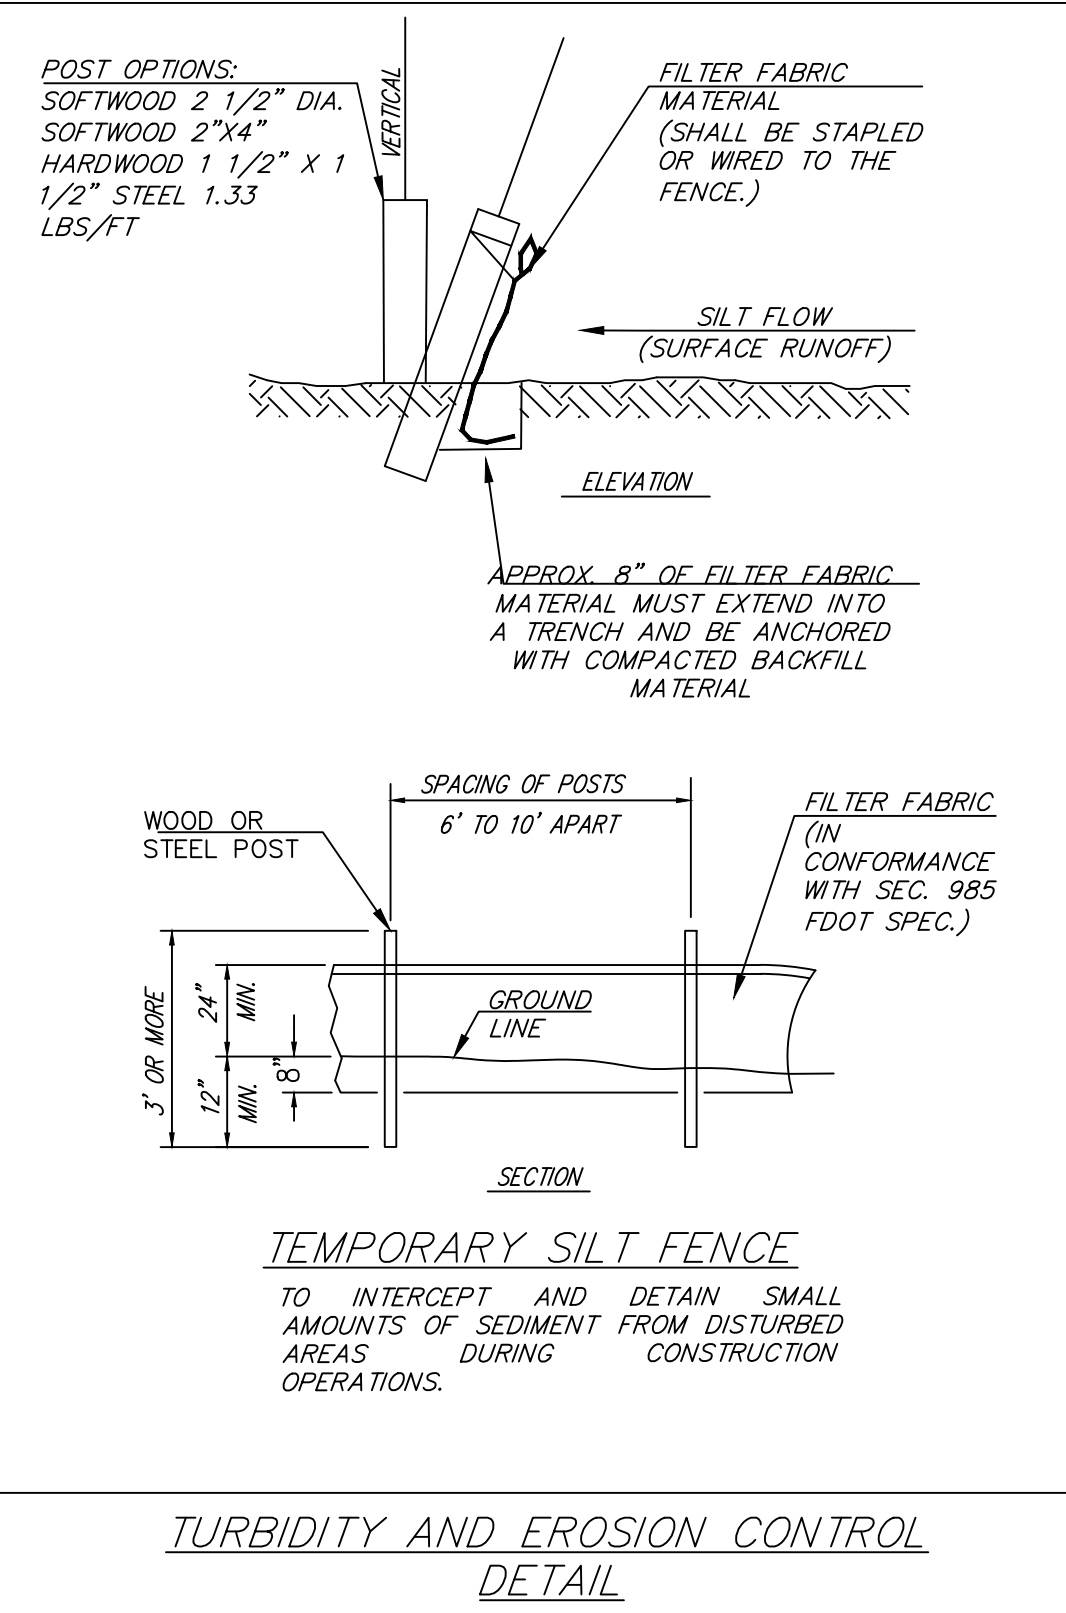

Sunshine
Call 811 or www.sunshine811.com two full business days before digging to have utilities located and marked.
Check positive response codes before you dig!

ENGINEER'S CERTIFICATION:

I HEREBY CERTIFY: That this plan was prepared under my direction and to the best of my knowledge and belief complies with the intent of the "MANUAL OF UNIFORM STANDARDS FOR DESIGN, CONSTRUCTION AND MAINTENANCE FOR STREETS, AND HIGHWAYS", as adopted by the State of Florida Legislature, Chapter 72-328 F.S.

REVISIONS	
02.14.20	BCC COMMENTS


DRAWING TITLE	
STORM WATER POLLUTION PREVENTION PLAN	
SCALE AS NOTED	
ISSUE DATE: 12.16.19	PROJECT NO. 1906
SHEET: C-7	

RODRIGUEZ ARCHITECTS INCORPORATED
2121 PONCE DE LEON BLVD. STE. 1010
CORAL GABLES, FL. 33134
TEL: (305) 448-3373
FAX: (305) 448-3374
A A C — 0 0 1 9 3 3

RAI

VENETIAN PARC WEST K-5 SCHOOL

SOUTHWEST 157th AVENUE and 174th STREET
MIAMI, FL. 33187
MDCPS PROJECT No. 01892600

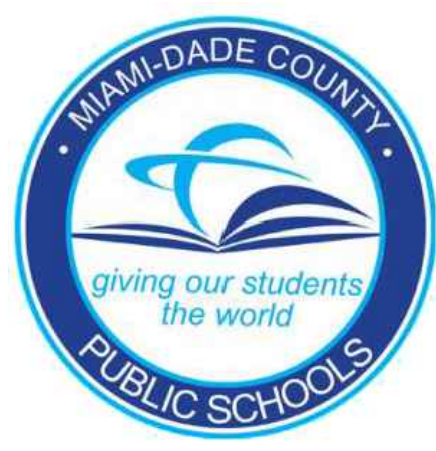

CONSULTANT INFO:




CHECKED BY: N.V.	DRAWN BY: C.O.
------------------	----------------



STORM WATER POLLUTION PREVENTION PLAN


SCALE: 1" = 30'

KEY PLAN

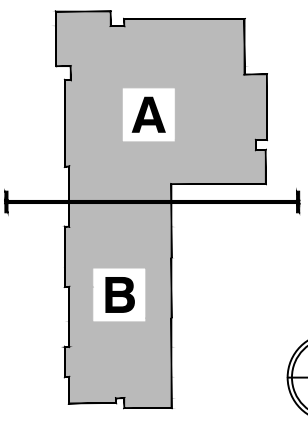

CONSULTANT INFO:

Jorge R. Avila
PE No. 22207

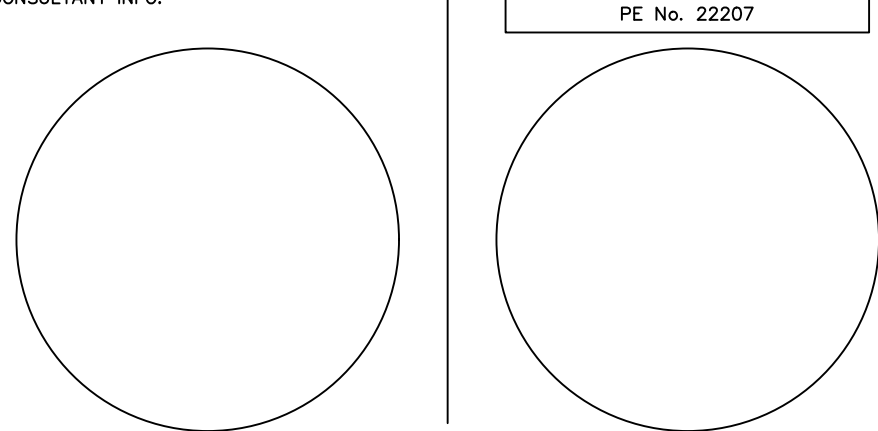

INDEX OF SHEETS

WS-1 WATER & SEWER COVER SHEET
WS-2 WATER & SEWER PLAN
WS-3 WATER & SEWER PROFILES

DEMOLITION NOTES:

(NOT A PART OF M-DWASD NOTES NOR APPROVAL)

- UNLESS OTHERWISE NOTED, ALL EXISTING IMPROVEMENTS WITHIN THE LIMITS OF WORK SHALL BE REMOVED IN THEIR ENTIRETY.
- ASPHALT PAVEMENT DESIGNATED FOR DEMOLITION SHALL BE REMOVED AND DISPOSED OF OFF-SITE AT AN APPROVED LOCATION. MAINS OUT AT PAVEMENT EDGES WHERE EXISTING PAVEMENT IS TO REMAIN.
- IN GREEN AREAS, EXISTING LIMESTONE SUBBASE SHALL BE SACRIFICED TO ITS FULL DEPTH AND SHARED TO THE LINES AND GRADES SHOWN IN THESE DRAWINGS.
- ALL EXISTING DRAINAGE IMPROVEMENTS WITHIN THE LIMITS OF WORK, IF ANY, SHALL BE REMOVED, INCLUDING STRUCTURES, PIPES, AND FRENCH DRAINS.

RER-DERM WATER-SEWER GENERAL NOTES:

(NOT A PART OF M-DWASD NOTES NOR APPROVAL)

- A HORIZONTAL DISTANCE OF AT LEAST 6 FEET, AND PREFERABLY 10 FEET (OUTSIDE TO OUTSIDE), SHALL BE MAINTAINED BETWEEN GRAVITY OR PRESSURE SEWER PIPES AND WATER PIPES. THE MINIMUM HORIZONTAL SEPARATION CAN BE REDUCED TO 3 FEET FOR VACUUM-TYPE SEWERS OR FOR GRAVITY SEWERS WHERE THE TOP OF THE SEWER PIPE IS AT LEAST 6 INCHES BELOW THE BOTTOM OF THE WATER PIPE, WHEN THE ABOVE SPECIFIED HORIZONTAL DISTANCE CRITERIA CANNOT BE MET DUE TO AN EXISTING UNDERGROUND FACILITY CONFLICT. SMALLER SEPARATIONS ARE ALLOWED IF ONE OF THE FOLLOWING IS MET:

A) THE SEWER PIPES ARE DESIGNED AND CONSTRUCTED EQUAL TO THE WATER PIPE AND PRESSURE TESTED AT 150 PSI.

B) THE SEWER IS ENCASED IN A WATERTIGHT CARRIER PIPE OR CONCRETE.

C) THE TOP OF THE SEWER IS AT LEAST 18 INCHES BELOW THE BOTTOM OF THE WATER PIPE.

2. A VERTICAL DISTANCE OF AT LEAST 12 INCHES (OUTSIDE TO OUTSIDE) SHALL BE MAINTAINED BETWEEN ANY WATER AND SEWER MAINS WITH SEWER MAINS PREFERABLY CROSSING UNDER WATER MAINS. THE MINIMUM VERTICAL SEPARATION CAN BE REDUCED TO 6 INCHES FOR VACUUM-TYPE SEWERS OR FOR GRAVITY SEWERS WHERE THE SEWER PIPE IS BELOW THE WATER MAIN. THE CROSSING SHALL BE ARRANGED SO THAT ALL WATER MAIN JOINTS ARE AT LEAST 6 FEET FROM ALL JOINTS IN GRAVITY AND PRESSURE SEWER PIPES. THIS DISTANCE CAN BE REDUCED TO 3 FEET FOR VACUUM-TYPE SEWERS. WHEN THE ABOVE SPECIFIED VERTICAL DISTANCE CRITERIA CANNOT BE MET DUE TO AN EXISTING UNDERGROUND FACILITY CONFLICT, SMALLER SEPARATIONS ARE ALLOWED IF ONE OF THE FOLLOWING IS MET:

A) THE SEWER PIPES ARE DESIGNED AND CONSTRUCTED EQUAL TO THE WATER PIPE AND PRESSURE TESTED AT 150 PSI.

B) THE SEWER IS ENCASED IN A WATERTIGHT CARRIER PIPE OR CONCRETE.

C) AIR RELEASE VALVES SHALL BE PROVIDED AT HIGH POINTS OF NEW FORCE MAIN SANITARY SEWERS.

4. GRAVITY SANITARY SEWERS CONSTRUCTED WITHIN A PUBLIC WELDFIELD PROTECTION AREA SHALL BE C-900 PVC OR DUCTILE IRON PIPE. THE MAXIMUM ALLOWABLE EXFILTRATION RATE OF GRAVITY SANITARY SEWERS CONSTRUCTED IN A PUBLIC WELDFIELD PROTECTION AREA SHALL BE ONE HUNDRED (100) GALLONS PER INCH PIPE DIAMETER PER MILE PER DAY.

A) RESIDENTIAL LAND USES. FIFTY (50) GALLONS PER INCH PIPE DIAMETER PER MILE PER DAY, BASED ON A MINIMUM TWO (2) HOUR TEST HAVING A MINIMUM OF TWO (2) FEET OF POSITIVE HEAD ABOVE THE CROWN OF THE PIPE.

B) NON-RESIDENTIAL LAND USES. TWENTY (20) GALLONS PER INCH PIPE DIAMETER PER MILE PER DAY, BASED ON A MINIMUM TWO (2) HOUR TEST HAVING A MINIMUM OF TWO (2) FEET OF POSITIVE HEAD ABOVE THE CROWN OF THE PIPE.

C) ANY OBSERVED LEAKS OR ANY OBVIOUSLY DEFECTIVE JOINTS OR PIPES SHALL BE REPLACED EVEN WHEN THE TOTAL LEAKAGE IS BELOW THAT ALLOWED.

5. THE MAXIMUM ALLOWABLE EXFILTRATION RATE OF GRAVITY SANITARY SEWERS CONSTRUCTED OUTSIDE A PUBLIC WELDFIELD PROTECTION AREA SHALL BE ONE HUNDRED (100) GALLONS PER INCH PIPE DIAMETER PER MILE PER DAY, BASED ON A MINIMUM TWO (2) HOUR TEST HAVING A MINIMUM OF TWO (2) FEET OF POSITIVE HEAD ABOVE THE CROWN OF THE PIPE. ANY OBSERVED LEAKS OR ANY OBVIOUSLY DEFECTIVE JOINTS OR PIPES SHALL BE REPLACED EVEN WHEN THE TOTAL LEAKAGE IS BELOW THAT ALLOWED.

6. FORCEMAIN SANITARY SEWERS CONSTRUCTED WITHIN A PUBLIC WELDFIELD PROTECTION AREA SHALL BE DUCTILE IRON, C-900 PVC, HDPE OR REINFORCED CONCRETE PRESSURE SEWER PIPES.

7. THE MAXIMUM ALLOWABLE EXFILTRATION/LEAKAGE RATE OF FORCE MAIN SANITARY SEWERS SHALL BE:

A) DUCTILE IRON, C-900 PVC, HDPE AND PVC PIPE. THE ALLOWABLE LEAKAGE RATE SPECIFIED IN AMERICAN WATER WORKS ASSOCIATION STANDARD (AWWA) C600-82 AT A TEST PRESSURE OF 100 PSI FOR A DURATION OF NOT LESS THAN TWO (2) HOURS.

B) REINFORCED CONCRETE PRESSURE PIPE, HALF (1/2) THE ALLOWABLE LEAKAGE RATE SPECIFIED IN AWWA C600-82 AT A TEST PRESSURE OF 100 PSI FOR A DURATION OF NOT LESS THAN TWO (2) HOURS.

C) ANY OBSERVED LEAKS OR ANY OBVIOUSLY DEFECTIVE JOINTS OR PIPES SHALL BE REPLACED EVEN WHEN THE TOTAL LEAKAGE IS BELOW THAT ALLOWED.

8. THE CONTRACTOR SHALL VERIFY NATURE, DEPTH, AND CHARACTER OF EXISTING UNDERGROUND UTILITIES PRIOR TO START OF CONSTRUCTION.

9. IN NO CASE SHALL A CONTRACTOR INSTALL UTILITY PIPES, CONDUITS, CABLES, ETC. IN THE SAME TRENCH ABOVE AN EXISTING WATER OR SEWER PIPE EXCEPT WHERE THEY CROSS.

10. IF ANY AREA OF THE WORK SITE IS FOUND TO CONTAIN BURIED SOLID WASTE AND/OR GROUND OR GROUND WATER CONTAMINATION, THE FOLLOWING SHALL APPLY:

A) ALL WORK IN THE AREA SHALL FOLLOW ALL APPLICABLE SAFETY REQUIREMENTS (E.G., OSHA, ETC.) AND NOTIFICATION MUST BE PROVIDED TO THE APPROPRIATE AGENCIES.

B) IMMEDIATELY NOTIFY THE ENVIRONMENTAL MONITORING AND RESTORATION DIVISION (EMRD). THE EMRD CAN BE CONTACTED AT (305) 372-6700.

C) IF CONTAMINATED SOILS AND/OR BURIED SOLID WASTE MATERIAL IS EXCAVATED DURING CONSTRUCTION, THEN THEY REQUIRE PROPER HANDLING AND DISPOSAL IN ACCORDANCE WITH THE LOCAL, STATE AND FEDERAL REGULATIONS. BE ADVISED THAT THE LANDFILL OWNER/OPERATOR IS THE FINAL AUTHORITY ON DISPOSAL AND MAY HAVE REQUIREMENTS BEYOND THOSE PROVIDED BY HEREIN. IF DISPOSAL WITHIN A MIAMI-DADE COUNTY OWNED LANDFILL (CLASS I LANDFILL) IS APPROPRIATE AND SELECTED, PLEASE CONTACT THE MIAMI-DADE COUNTY DEPARTMENT OF SOLID WASTE MANAGEMENT AT (305) 594-6666 FOR INFORMATION.

D) THE REUSE OF CONTAMINATED SOILS THAT ARE NOT RETURNED TO THE ORIGINAL EXCAVATION REQUIRES PRIOR APPROVAL OF A SOL MANAGEMENT PLAN FROM THE ENVIRONMENTAL MONITORING AND RESTORATION DIVISION. THE EMRD CAN BE CONTACTED AT (305) 372-6700.

11. PUMPS MUST COMPLY WITH THE NATIONAL ELECTRICAL CODE (NEC) REQUIREMENTS FOR CLASS I, GROUP D, DIVISION 1 LOCATIONS (EXPLOSION PROOF).

12. THE CONTRACTOR IS ADVISED THAT A TREE REMOVAL/RELOCATION PERMIT MAY BE REQUIRED PRIOR TO THE REMOVAL AND/OR RELOCATION OF TREE RESOURCES. PRIOR TO REMOVING OR RELOCATING ANY TREES, THE CONTRACTOR SHALL NOTIFY THE TREE AND FOREST RESOURCES SECTION OF DERW AT (305) 372-6574 OR VIA E-MAIL AT: DERW@MIAMI-DADE.GOV OR CONTACT THE MUNICIPALITY WITH TREE ORDINANCE JURISDICTION TO OBTAIN ANY REQUIRED PERMITS. THOSE TREES NOT INTERFERING WITH THE CONSTRUCTION SHALL BE PROTECTED IN PLACE IN ACCORDANCE WITH THE PROVISIONS OF SECTION 24-49.5 OF THE MIAMI-DADE CODE.

13. PLEASE NOTE THAT THE DEMOLITION, REMOVAL, AND/OR DISTURBANCE OF EXISTING UNDERGROUND UTILITIES THAT CONTAIN ASBESTOS-CEMENT PIPES (ACP) ARE SUBJECT TO THE PROVISIONS OF 40 CFR-61.154, AND 40 CFR-61.151. A YEAR AFTER PROJECT COMPLETION, EXISTING STANDARD OPERATING PROCEDURES, AS WELL AS APPLICABLE FEDERAL, STATE, AND LOCAL REGULATORY CRITERIA, MUST BE FOLLOWED AND IMPLEMENTED TO MINIMIZE ANY POTENTIAL RELEASE OF FUGITIVE EMISSIONS, ESPECIALLY DURING PROJECT CONSTRUCTION ACTIVITIES. THE ACPD CAN BE CONTACTED VIA EMAIL AT ASBESTOS@MIAMI-DADE.GOV OR 305.372.9295.

REVISION 04/30/2018

TRENCH SAFETY ACT

(NOT A PART OF M-DWASD NOTES NOR APPROVAL)

CONTRACTOR SHALL COMPLY WITH THE REQUIREMENTS OF THE "TRENCH SAFETY ACT", AND ALL REQUIREMENTS OF O.S.H.A.

SANITARY SEWER SYSTEM NOTES:

(NOT A PART OF M-DWASD NOTES NOR APPROVAL)

- SANITARY MANHOLES AND LIDS SHALL BE CAPABLE OF WITHSTANDING H=20 WHEEL LOAD. THE WORDS "SANITARY SEWER" SHALL BE CAST INTO ALL SANITARY MANHOLE LIDS.
- ALL GRAVITY SEWER PIPE SHALL BE PVC OR DUCTILE IRON. PVC PIPE SHALL CONFORM TO ASTM D-3034, SDR 35, LATEST REVISION, WITH MAXIMUM 13 FOOT LENGTHS AND PUSH-ON RUBBER GASKET JOINTS.
- THE MINIMUM DESIGN SLOPES FOR 8" GRAVITY SEWER PIPES SHALL BE @ 0.40%.
- THE CONTRACTOR SHALL TEST THE COMPLETED SEWER LINE TO DETERMINE ALIGNMENT AND TIGHTNESS OF THE JOINTS. TESTING SHALL BE LAMPED AND MUST SHOW A FULL CIRCLE OF LIGHT. INFILTRATION AND EXFILTRATION TESTING SHALL BE CONDUCTED.
- CLEAN OUTS SHALL BE INSTALLED AT MAXIMUM 75 FOOT INTERVALS ON ALL SEWER SERVICES EXCEEDING 75 FEET IN LENGTH.
- DUCTILE IRON PIPE SHALL CONFORM TO THE REQUIREMENTS OF ANSI/AWWA C151/A21.51-86 AND SHALL BE ASPHALT COATED OUTSIDE PER ANSI/AWWA C104/A21.4-90.
- ALL DUCTILE IRON PIPE (DIP) SHALL BE INSTALLED WITH A MINIMUM CLEAR COVER OF 36 INCHES.
- INSTALLATION AND TESTING OF MAINS SHALL BE DONE IN ACCORDANCE WITH MIAMI-DADE COUNTY WATER AND SEWER DEPARTMENT STANDARDS AND SPECIFICATIONS.
- CONNECTING TO THE EXISTING SYSTEM. ALL CONNECTIONS TO EXISTING MAINS SHALL BE MADE UNDER THE DIRECTION OF THE ENGINEER AND MIAMI-DADE COUNTY WATER AND SEWER DEPARTMENT'S INSPECTOR.

GENERAL NOTES:

(NOT A PART OF M-DWASD NOTES NOR APPROVAL)

- VERTICAL CONTROL POINTS AND ALL ELEVATIONS ARE BASED ON 1929 NGVD DATUM.
- ALL EXISTING UTILITIES SHALL REMAIN IN SERVICE, UNLESS OTHERWISE NOTED.
- USE EXTREME CAUTION NEAR ALL UTILITIES, CABLES, CONDUITS, AND MANHOLES. CONTRACTOR TO PROVIDE PROTECTION DURING CONSTRUCTION TO ASSURE SERVICE AT ALL TIMES. CONTRACTOR SHALL COORDINATE ALL SCHEDULES WITH FIELD REPRESENTATIVE PRIOR TO WORKING AROUND UTILITIES.

4. ALL CONSTRUCTION LAYOUT SHALL BE THE RESPONSIBILITY OF THE CONTRACTOR. THE CONTRACTOR SHALL BE RESPONSIBLE FOR ESTABLISHING THE WORK LIMIT LINES AS SHOWN ON THE PLANS AND SHALL WORK WITHIN THE LIMITS AND DIMENSIONS SHOWN.

ALL PAVEMENT DIMENSIONS ARE TO THE EDGE OF PAVEMENT. ANY DEVIATION FROM THE PLANS SHALL REQUIRE WRITTEN APPROVAL FROM THE ENGINEER PRIOR TO EXECUTING WORK.

5. CONTRACTOR SHALL BE RESPONSIBLE FOR PROTECTING AND RESTORING ALL ADJACENT IMPROVEMENTS. CONTRACTOR SHALL BE RESPONSIBLE FOR RESETTling ALL DISTURBED EXISTING MANHOLE COVERS, VALVE BOXES, BLOW-OFF RISERS, ETC. TO NEW ELEVATIONS, AS REQUIRED, WHETHER SPECIFICALLY SHOWN ON DRAWINGS OR NOT.

6. THE CONTRACTOR SHALL NOTIFY ALL UTILITY COMPANIES THAT MAY BE AFFECTED BY THE PROPOSED WORK, PRIOR TO THE START OF ANY CONSTRUCTION, TO ARRANGE FOR PHYSICAL LOCATION AND ELEVATION OF ALL UNDERGROUND IMPROVEMENTS. IT IS THE CONTRACTOR'S RESPONSIBILITY TO PROVIDE THE UTILITY COMPANY SUFFICIENT NOTICE TO SCHEDULE ANY RELOCATION OF THEIR UTILITIES. THE CONTRACTOR SHALL BE RESPONSIBLE FOR SUPPORT OF ANY UTILITY THAT MAY BE IN CONFLICT WITH OR ENDANGERED BY THE PROPOSED WORK.

7. COMPLETE "AS-BUILT" INFORMATION RELATIVE TO LOCATION, SIZE AND DEPTH OF THE PROPOSED PIPES, STRUCTURES, AND OTHER IMPROVEMENTS SHALL BE ACCURATELY RECORDED. THIS INFORMATION SHALL BE SUBMITTED TO THE ENGINEER AS A CADD FILE AND AS A DRAWING SIGNED AND SEALED BY A PROFESSIONAL LAND SURVEYOR REGISTERED IN THE STATE OF FLORIDA AT THE CONTRACTOR'S EXPENSE.

8. THE UNDERGROUND UTILITIES SHOWN HEREON ARE BASED ON EXISTING UTILITY PLANS. NO SUBSURFACE VERIFICATION OF THE UTILITIES WAS MADE. SOME UTILITIES MAY NOT BE REFLECTED IN THESE PLANS. BEFORE EXCAVATION OR CONSTRUCTION, CONTACT THE SUNSHINE ONE CALL SERVICE #811 AND THE APPROPRIATE UTILITY COMPANIES FOR FIELD VERIFICATION. SUBSURFACE CASINGS, DUCT BANKS, FOOTINGS, FOUNDATIONS, AND OTHER SUBSURFACE FEATURES ARE NOT LOCATED OR SHOWN HEREON. ARE TO CONTRACTOR BEFORE COMMENCING ANY WORK.

9. THE CONTRACTOR SHALL BE RESPONSIBLE FOR MAINTAINING THE INTEGRITY AND MAKING THE REPAIRS OF EXISTING PAVEMENT, SIDEWALKS, PIPES, CONDUITS, CURBS, CABLES, ETC. SHOWN ON THE PLANS, BECAUSE AS A RESULT OF THE CONTRACTOR'S OPERATIONS AND/OR THOSE OF HIS SUBCONTRACTORS, AND SHALL RESTORE THEM PROMPTLY TO THE ORIGINAL CONDITIONS OR BETTER AT NO ADDITIONAL EXPENSE TO THE OWNER. CONTRACTOR SHALL REPORT ANY DAMAGED SIDEWALK, DRIVEWAY, ETC., PRIOR TO BEGINNING WORK IN ANY AREA.

10. EXISTING WATER METERS, UTILITY POLES & GUY WIRES AND OTHER UTILITIES WITHIN THE LIMITS OF CONSTRUCTION SHALL BE REMOVED OR RELOCATED UNLESS OTHERWISE NOTED.

11. ALL WORK SHALL CONFORM TO ALL APPLICABLE CODES, ORDINANCES OF M-D WASD STANDARDS AND DETAILS, FLORIDA DEPARTMENT OF TRANSPORTATION STANDARDS AND DETAILS, AND MIAMI-DADE COUNTY STANDARDS AND DETAILS.

12. THE CONTRACTOR SHALL BE RESPONSIBLE FOR MAINTAINING THE INTEGRITY AND MAKING THE REPAIRS OF EXISTING PAVEMENT, SIDEWALKS, PIPES, CONDUITS, CURBS, CABLES, ETC. SHOWN ON THE PLANS, BECAUSE AS A RESULT OF THE CONTRACTOR'S OPERATIONS AND/OR THOSE OF HIS SUBCONTRACTORS, AND SHALL RESTORE THEM PROMPTLY TO THE ORIGINAL CONDITIONS OR BETTER AT NO ADDITIONAL EXPENSE TO THE OWNER. CONTRACTOR SHALL REPORT ANY DAMAGED SIDEWALK, DRIVEWAY, ETC., PRIOR TO BEGINNING WORK IN ANY AREA.

13. THE CONTRACTOR SHALL BE RESPONSIBLE FOR MAINTAINING THE INTEGRITY AND MAKING THE REPAIRS OF EXISTING PAVEMENT, SIDEWALKS, PIPES, CONDUITS, CURBS, CABLES, ETC. SHOWN ON THE PLANS, BECAUSE AS A RESULT OF THE CONTRACTOR'S OPERATIONS AND/OR THOSE OF HIS SUBCONTRACTORS, AND SHALL RESTORE THEM PROMPTLY TO THE ORIGINAL CONDITIONS OR BETTER AT NO ADDITIONAL EXPENSE TO THE OWNER. CONTRACTOR SHALL REPORT ANY DAMAGED SIDEWALK, DRIVEWAY, ETC., PRIOR TO BEGINNING WORK IN ANY AREA.

14. THE CONTRACTOR SHALL BE RESPONSIBLE FOR MAINTAINING THE INTEGRITY AND MAKING THE REPAIRS OF EXISTING PAVEMENT, SIDEWALKS, PIPES, CONDUITS, CURBS, CABLES, ETC. SHOWN ON THE PLANS, BECAUSE AS A RESULT OF THE CONTRACTOR'S OPERATIONS AND/OR THOSE OF HIS SUBCONTRACTORS, AND SHALL RESTORE THEM PROMPTLY TO THE ORIGINAL CONDITIONS OR BETTER AT NO ADDITIONAL EXPENSE TO THE OWNER. CONTRACTOR SHALL REPORT ANY DAMAGED SIDEWALK, DRIVEWAY, ETC., PRIOR TO BEGINNING WORK IN ANY AREA.

15. THE CONTRACTOR SHALL BE RESPONSIBLE FOR MAINTAINING THE INTEGRITY AND MAKING THE REPAIRS OF EXISTING PAVEMENT, SIDEWALKS, PIPES, CONDUITS, CURBS, CABLES, ETC. SHOWN ON THE PLANS, BECAUSE AS A RESULT OF THE CONTRACTOR'S OPERATIONS AND/OR THOSE OF HIS SUBCONTRACTORS, AND SHALL RESTORE THEM PROMPTLY TO THE ORIGINAL CONDITIONS OR BETTER AT NO ADDITIONAL EXPENSE TO THE OWNER. CONTRACTOR SHALL REPORT ANY DAMAGED SIDEWALK, DRIVEWAY, ETC., PRIOR TO BEGINNING WORK IN ANY AREA.

16. THE CONTRACTOR SHALL BE RESPONSIBLE FOR MAINTAINING THE INTEGRITY AND MAKING THE REPAIRS OF EXISTING PAVEMENT, SIDEWALKS, PIPES, CONDUITS, CURBS, CABLES, ETC. SHOWN ON THE PLANS, BECAUSE AS A RESULT OF THE CONTRACTOR'S OPERATIONS AND/OR THOSE OF HIS SUBCONTRACTORS, AND SHALL RESTORE THEM PROMPTLY TO THE ORIGINAL CONDITIONS OR BETTER AT NO ADDITIONAL EXPENSE TO THE OWNER. CONTRACTOR SHALL REPORT ANY DAMAGED SIDEWALK, DRIVEWAY, ETC., PRIOR TO BEGINNING WORK IN ANY AREA.

17. THE CONTRACTOR SHALL BE RESPONSIBLE FOR MAINTAINING THE INTEGRITY AND MAKING THE REPAIRS OF EXISTING PAVEMENT, SIDEWALKS, PIPES, CONDUITS, CURBS, CABLES, ETC. SHOWN ON THE PLANS, BECAUSE AS A RESULT OF THE CONTRACTOR'S OPERATIONS AND/OR THOSE OF HIS SUBCONTRACTORS, AND SHALL RESTORE THEM PROMPTLY TO THE ORIGINAL CONDITIONS OR BETTER AT NO ADDITIONAL EXPENSE TO THE OWNER. CONTRACTOR SHALL REPORT ANY DAMAGED SIDEWALK, DRIVEWAY, ETC., PRIOR TO BEGINNING WORK IN ANY AREA.

18. THE CONTRACTOR SHALL BE RESPONSIBLE FOR MAINTAINING THE INTEGRITY AND MAKING THE REPAIRS OF EXISTING PAVEMENT, SIDEWALKS, PIPES, CONDUITS, CURBS, CABLES, ETC. SHOWN ON THE PLANS, BECAUSE AS A RESULT OF THE CONTRACTOR'S OPERATIONS AND/OR THOSE OF HIS SUBCONTRACTORS, AND SHALL RESTORE THEM PROMPTLY TO THE ORIGINAL CONDITIONS OR BETTER AT NO ADDITIONAL EXPENSE TO THE OWNER. CONTRACTOR SHALL REPORT ANY DAMAGED SIDEWALK, DRIVEWAY, ETC., PRIOR TO BEGINNING WORK IN ANY AREA.

19. THE CONTRACTOR SHALL BE RESPONSIBLE FOR MAINTAINING THE INTEGRITY AND MAKING THE REPAIRS OF EXISTING PAVEMENT, SIDEWALKS, PIPES, CONDUITS, CURBS, CABLES, ETC. SHOWN ON THE PLANS, BECAUSE AS A RESULT OF THE CONTRACTOR'S OPERATIONS AND/OR THOSE OF HIS SUBCONTRACTORS, AND SHALL RESTORE THEM PROMPTLY TO THE ORIGINAL CONDITIONS OR BETTER AT NO ADDITIONAL EXPENSE TO THE OWNER. CONTRACTOR SHALL REPORT ANY DAMAGED SIDEWALK, DRIVEWAY, ETC., PRIOR TO BEGINNING WORK IN ANY AREA.

20. THE CONTRACTOR SHALL BE RESPONSIBLE FOR MAINTAINING THE INTEGRITY AND MAKING THE REPAIRS OF EXISTING PAVEMENT, SIDEWALKS, PIPES, CONDUITS, CURBS, CABLES, ETC. SHOWN ON THE PLANS, BECAUSE AS A RESULT OF THE CONTRACTOR'S OPERATIONS AND/OR THOSE OF HIS SUBCONTRACTORS, AND SHALL RESTORE THEM PROMPTLY TO THE ORIGINAL CONDITIONS OR BETTER AT NO ADDITIONAL EXPENSE TO THE OWNER. CONTRACTOR SHALL REPORT ANY DAMAGED SIDEWALK, DRIVEWAY, ETC., PRIOR TO BEGINNING WORK IN ANY AREA.

21. THE CONTRACTOR SHALL BE RESPONSIBLE FOR MAINTAINING THE INTEGRITY AND MAKING THE REPAIRS OF EXISTING PAVEMENT, SIDEWALKS, PIPES, CONDUITS, CURBS, CABLES, ETC. SHOWN ON THE PLANS, BECAUSE AS A RESULT OF THE CONTRACTOR'S OPERATIONS AND/OR THOSE OF HIS SUBCONTRACTORS, AND SHALL RESTORE THEM PROMPTLY TO THE ORIGINAL CONDITIONS OR BETTER AT NO ADDITIONAL EXPENSE TO THE OWNER. CONTRACTOR SHALL REPORT ANY DAMAGED SIDEWALK, DRIVEWAY, ETC., PRIOR TO BEGINNING WORK IN ANY AREA.

22. THE CONTRACTOR SHALL BE RESPONSIBLE FOR MAINTAINING THE INTEGRITY AND MAKING THE REPAIRS OF EXISTING PAVEMENT, SIDEWALKS, PIPES, CONDUITS, CURBS, CABLES, ETC. SHOWN ON THE PLANS, BECAUSE AS A RESULT OF THE CONTRACTOR'S OPERATIONS AND/OR THOSE OF HIS SUBCONTRACTORS, AND SHALL RESTORE THEM PROMPTLY TO THE ORIGINAL CONDITIONS OR BETTER AT NO ADDITIONAL EXPENSE TO THE OWNER. CONTRACTOR SHALL REPORT ANY DAMAGED SIDEWALK, DRIVEWAY, ETC., PRIOR TO BEGINNING WORK IN ANY AREA.

23. THE CONTRACTOR SHALL BE RESPONSIBLE FOR MAINTAINING THE INTEGRITY AND MAKING THE REPAIRS OF EXISTING PAVEMENT, SIDEWALKS, PIPES, CONDUITS, CURBS, CABLES, ETC. SHOWN ON THE PLANS, BECAUSE AS A RESULT OF THE CONTRACTOR'S OPERATIONS AND/OR THOSE OF HIS SUBCONTRACTORS, AND SHALL RESTORE THEM PROMPTLY TO THE ORIGINAL CONDITIONS OR BETTER AT NO ADDITIONAL EXPENSE TO THE OWNER. CONTRACTOR SHALL REPORT ANY DAMAGED SIDEWALK, DRIVEWAY, ETC., PRIOR TO BEGINNING WORK IN ANY AREA.

24. THE CONTRACTOR SHALL BE RESPONSIBLE FOR MAINTAINING THE INTEGRITY AND MAKING THE REPAIRS OF EXISTING PAVEMENT, SIDEWALKS, PIPES, CONDUITS, CURBS, CABLES, ETC. SHOWN ON THE PLANS, BECAUSE AS A RESULT OF THE CONTRACTOR'S OPERATIONS AND/OR THOSE OF HIS SUBCONTRACTORS, AND SHALL RESTORE THEM PROMPTLY TO THE ORIGINAL CONDITIONS OR BETTER AT NO ADDITIONAL EXPENSE TO THE OWNER. CONTRACTOR SHALL REPORT ANY DAMAGED SIDEWALK, DRIVEWAY, ETC., PRIOR TO BEGINNING WORK IN ANY AREA.

25. THE CONTRACTOR SHALL BE RESPONSIBLE FOR MAINTAINING THE INTEGRITY AND MAKING THE REPAIRS OF EXISTING PAVEMENT, SIDEWALKS, PIPES, CONDUITS, CURBS, CABLES, ETC. SHOWN ON THE PLANS, BECAUSE AS A RESULT OF THE CONTRACTOR'S OPERATIONS AND/OR THOSE OF HIS SUBCONTRACTORS, AND SHALL RESTORE THEM PROMPTLY TO THE ORIGINAL CONDITIONS OR BETTER AT NO ADDITIONAL EXPENSE TO THE OWNER. CONTRACTOR SHALL REPORT ANY DAMAGED SIDEWALK, DRIVEWAY, ETC., PRIOR TO BEGINNING WORK IN ANY AREA.

26. THE CONTRACTOR SHALL BE RESPONSIBLE FOR MAINTAINING THE INTEGRITY AND MAKING THE REPAIRS OF EXISTING PAVEMENT, SIDEWALKS, PIPES, CONDUITS, CURBS, CABLES, ETC. SHOWN ON THE PLANS, BECAUSE AS A RESULT OF THE CONTRACTOR'S OPERATIONS AND/OR THOSE OF HIS SUBCONTRACTORS, AND SHALL RESTORE THEM PROMPTLY TO THE ORIGINAL CONDITIONS OR BETTER AT NO ADDITIONAL EXPENSE TO THE OWNER. CONTRACTOR SHALL REPORT ANY DAMAGED SIDEWALK, DRIVEWAY, ETC., PRIOR TO BEGINNING WORK IN ANY AREA.

27. THE CONTRACTOR SHALL BE RESPONSIBLE FOR MAINTAINING THE INTEGRITY AND MAKING THE REPAIRS OF EXISTING PAVEMENT, SIDEWALKS, PIPES, CONDUITS, CURBS, CABLES, ETC. SHOWN ON THE PLANS, BECAUSE AS A RESULT OF THE CONTRACTOR'S OPERATIONS AND/OR THOSE OF HIS SUBCONTRACTORS, AND SHALL RESTORE THEM PROMPTLY TO THE ORIGINAL CONDITIONS OR BETTER AT NO ADDITIONAL EXPENSE TO THE OWNER. CONTRACTOR SHALL REPORT ANY DAMAGED SIDEWALK, DRIVEWAY, ETC., PRIOR TO BEGINNING WORK IN ANY AREA.

28. THE CONTRACTOR SHALL BE RESPONSIBLE FOR MAINTAINING THE INTEGRITY AND MAKING THE REPAIRS OF EXISTING PAVEMENT, SIDEWALKS, PIPES, CONDUITS, CURBS, CABLES, ETC. SHOWN ON THE PLANS, BECAUSE AS A RESULT OF THE CONTRACTOR'S OPERATIONS AND/OR THOSE OF HIS SUBCONTRACTORS, AND SHALL RESTORE THEM PROMPTLY TO THE ORIGINAL CONDITIONS OR BETTER AT NO ADDITIONAL EXPENSE TO THE OWNER. CONTRACTOR SHALL REPORT ANY DAMAGED SIDEWALK, DRIVEWAY, ETC., PRIOR TO BEGINNING WORK IN ANY AREA.

29. THE CONTRACTOR SHALL BE RESPONSIBLE FOR MAINTAINING THE INTEGRITY AND MAKING THE REPAIRS OF EXISTING PAVEMENT, SIDEWALKS, PIPES, CONDUITS, CURBS, CABLES, ETC. SHOWN ON THE PLANS, BECAUSE AS A RESULT OF THE CONTRACTOR'S OPERATIONS AND/OR THOSE OF HIS SUBCONTRACTORS, AND SHALL RESTORE THEM PROMPTLY TO THE ORIGINAL CONDITIONS OR BETTER AT NO ADDITIONAL EXPENSE TO THE OWNER. CONTRACTOR SHALL REPORT ANY DAMAGED SIDEWALK, DRIVEWAY, ETC., PRIOR TO BEGINNING WORK IN ANY AREA.

30. THE CONTRACTOR SHALL BE RESPONSIBLE FOR MAINTAINING THE INTEGRITY AND MAKING THE REPAIRS OF EXISTING PAVEMENT, SIDEWALKS, PIPES, CONDUITS, CURBS, CABLES, ETC. SHOWN ON THE PLANS, BECAUSE AS A RESULT OF THE CONTRACTOR'S OPERATIONS AND/OR THOSE OF HIS SUBCONTRACTORS, AND SHALL RESTORE THEM PROMPTLY TO THE ORIGINAL CONDITIONS OR BETTER AT NO ADDITIONAL EXPENSE TO THE OWNER. CONTRACTOR SHALL REPORT ANY DAMAGED SIDEWALK, DRIVEWAY, ETC., PRIOR TO BEGINNING WORK IN ANY AREA.

31. THE CONTRACTOR SHALL BE RESPONSIBLE FOR MAINTAINING THE INTEGRITY AND MAKING THE REPAIRS OF EXISTING PAVEMENT, SIDEWALKS, PIPES, CONDUITS, CURBS, CABLES, ETC. SHOWN ON THE PLANS, BECAUSE AS A RESULT OF THE CONTRACTOR'S OPERATIONS AND/OR THOSE OF HIS SUBCONTRACTORS, AND SHALL RESTORE THEM PROMPTLY TO THE ORIGINAL CONDITIONS OR BETTER AT NO ADDITIONAL EXPENSE TO THE OWNER. CONTRACTOR SHALL REPORT ANY DAMAGED SIDEWALK, DRIVEWAY, ETC., PRIOR TO BEGINNING WORK IN ANY AREA.

32. THE CONTRACTOR SHALL BE RESPONSIBLE FOR MAINTAINING THE INTEGRITY AND MAKING THE REPAIRS OF EXISTING PAVEMENT, SIDEWALKS, PIPES, CONDUITS, CURBS, CABLES, ETC. SHOWN ON THE PLANS, BECAUSE AS A RESULT OF THE CONTRACTOR'S OPERATIONS AND/OR THOSE OF HIS SUBCONTRACTORS, AND SHALL RESTORE THEM PROMPTLY TO THE ORIGINAL CONDITIONS OR BETTER AT NO ADDITIONAL EXPENSE TO THE OWNER. CONTRACTOR SHALL REPORT ANY DAMAGED SIDEWALK, DRIVEWAY, ETC., PRIOR TO BEGINNING WORK IN ANY AREA.

33. THE CONTRACTOR SHALL BE RESPONSIBLE FOR MAINTAINING THE INTEGRITY AND MAKING THE REPAIRS OF EXISTING PAVEMENT, SIDEWALKS, PIPES, CONDUITS, CURBS, CABLES, ETC. SHOWN ON THE PLANS, BECAUSE AS A RESULT OF THE CONTRACTOR'S OPERATIONS AND/OR THOSE OF HIS SUBCONTRACTORS, AND SHALL RESTORE THEM PROMPTLY TO THE ORIGINAL CONDITIONS OR BETTER AT NO ADDITIONAL EXPENSE TO THE OWNER. CONTRACTOR SHALL REPORT ANY DAMAGED SIDEWALK, DRIVEWAY, ETC., PRIOR TO BEGINNING WORK IN ANY AREA.

34. THE CONTRACTOR SHALL BE RESPONSIBLE FOR MAINTAINING THE INTEGRITY AND MAKING THE REPAIRS OF EXISTING PAVEMENT, SIDEWALKS, PIPES, CONDUITS, CURBS, CABLES, ETC. SHOWN ON THE PLANS, BECAUSE AS A RESULT OF THE CONTRACTOR'S OPERATIONS AND/OR THOSE OF HIS SUBCONTRACTORS, AND SHALL RESTORE THEM PROMPTLY TO THE ORIGINAL CONDITIONS OR BETTER AT NO ADDITIONAL EXPENSE TO THE OWNER. CONTRACTOR SHALL REPORT ANY DAMAGED SIDEWALK, DRIVEWAY, ETC., PRIOR TO BEGINNING WORK IN ANY AREA.

35. THE CONTRACTOR SHALL BE RESPONSIBLE FOR MAINTAINING THE INTEGRITY AND MAKING THE REPAIRS OF EXISTING PAVEMENT, SIDEWALKS, PIPES, CONDUITS, CURBS, CABLES, ETC. SHOWN ON THE PLANS, BECAUSE AS A RESULT OF THE CONTRACTOR'S OPERATIONS AND/OR THOSE OF HIS SUBCONTRACTORS, AND SHALL RESTORE THEM PROMPTLY TO THE ORIGINAL CONDITIONS OR BETTER AT NO ADDITIONAL EXPENSE TO THE OWNER. CONTRACTOR SHALL REPORT ANY DAMAGED SIDEWALK, DRIVEWAY, ETC., PRIOR TO BEGINNING WORK IN ANY AREA.

36. THE CONTRACTOR SHALL BE RESPONSIBLE FOR MAINTAINING THE INTEGRITY AND MAKING THE REPAIRS OF EXISTING PAVEMENT, SIDEWALKS, PIPES, CONDUITS, CURBS, CABLES, ETC. SHOWN ON THE PLANS, BECAUSE AS A RESULT OF THE CONTRACTOR'S OPERATIONS AND/OR THOSE OF HIS SUBCONTRACTORS, AND SHALL RESTORE THEM PROMPTLY TO THE ORIGINAL CONDITIONS OR BETTER AT NO ADDITIONAL EXPENSE TO THE OWNER. CONTRACTOR SHALL REPORT ANY DAMAGED SIDEWALK, DRIVEWAY, ETC., PRIOR TO BEGINNING WORK IN ANY AREA.

37. THE CONTRACTOR SHALL BE RESPONSIBLE FOR MAINTAINING THE INTEGRITY AND MAKING THE REPAIRS OF EXISTING PAVEMENT, SIDEWALKS, PIPES, CONDUITS, CURBS, CABLES, ETC. SHOWN ON THE PLANS, BECAUSE AS A RESULT OF THE CONTRACTOR'S OPERATIONS AND/OR THOSE OF HIS SUBCONTRACTORS, AND SHALL RESTORE THEM PROMPTLY TO THE ORIGINAL CONDITIONS OR BETTER AT NO ADDITIONAL EXPENSE TO THE OWNER. CONTRACTOR SHALL REPORT ANY DAMAGED SIDEWALK, DRIVEWAY, ETC., PRIOR TO BEGINNING WORK IN ANY AREA.

38. THE CONTRACTOR SHALL BE RESPONSIBLE FOR MAINTAINING THE INTEGRITY AND MAKING THE REPAIRS OF EXISTING PAVEMENT, SIDEWALKS, PIPES, CONDUITS, CURBS, CABLES, ETC. SHOWN ON THE PLANS, BECAUSE AS A RESULT OF THE CONTRACTOR'S OPERATIONS AND/OR THOSE OF HIS SUBCONTRACTORS, AND SHALL RESTORE THEM PROMPTLY TO THE ORIGINAL CONDITIONS OR BETTER AT NO ADDITIONAL EXPENSE TO THE OWNER. CONTRACTOR SHALL REPORT ANY DAMAGED SIDEWALK, DRIVEWAY, ETC., PRIOR TO BEGINNING WORK IN ANY AREA.

39. THE CONTRACTOR SHALL BE RESPONSIBLE FOR MAINTAINING THE INTEGRITY AND MAKING THE REPAIRS OF EXISTING PAVEMENT, SIDEWALKS, PIPES, CONDUITS, CURBS, CABLES, ETC. SHOWN ON THE PLANS, BECAUSE AS A RESULT OF THE CONTRACTOR'S OPERATIONS AND/OR THOSE OF HIS SUBCONTRACTORS, AND SHALL RESTORE THEM PROMPTLY TO THE ORIGINAL CONDITIONS OR BETTER AT NO ADDITIONAL EXPENSE TO THE OWNER. CONTRACTOR SHALL REPORT ANY DAMAGED SIDEWALK, DRIVEWAY, ETC., PRIOR TO BEGINNING WORK IN ANY AREA.

40. THE CONTRACTOR SHALL BE RESPONSIBLE FOR MAINTAINING THE INTEGRITY AND MAKING THE REPAIRS OF EXISTING PAVEMENT, SIDEWALKS, PIPES, CONDUITS, CURBS, CABLES, ETC. SHOWN ON THE PLANS, BECAUSE AS A RESULT OF THE CONTRACTOR'S OPERATIONS AND/OR THOSE OF HIS SUBCONTRACTORS, AND SHALL RESTORE THEM PROMPTLY TO THE ORIGINAL CONDITIONS OR BETTER AT NO ADDITIONAL EXPENSE TO THE OWNER. CONTRACTOR SHALL REPORT ANY DAMAGED SIDEWALK, DRIVEWAY, ETC., PRIOR TO BEGINNING WORK IN ANY AREA.

41. THE CONTRACTOR SHALL BE RESPONSIBLE FOR MAINTAINING THE INTEGRITY AND MAKING THE REPAIRS OF EXISTING PAVEMENT, SIDEWALKS, PIPES, CONDUITS, CURBS, CABLES, ETC. SHOWN ON THE PLANS, BECAUSE AS A RESULT OF THE CONTRACTOR'S OPERATIONS AND/OR THOSE OF HIS SUBCONTRACTORS, AND SHALL RESTORE THEM PROMPTLY TO THE ORIGINAL CONDITIONS OR BETTER AT NO ADDITIONAL EXPENSE TO THE OWNER. CONTRACTOR SHALL REPORT ANY DAMAGED SIDEWALK, DRIVEWAY, ETC., PRIOR TO BEGINNING WORK IN ANY AREA.

42. THE CONTRACTOR SHALL BE RESPONSIBLE FOR MAINTAINING THE INTEGRITY AND MAKING THE REPAIRS OF EXISTING PAVEMENT, SIDEWALKS, PIPES, CONDUITS, CURBS, CABLES, ETC. SHOWN ON THE PLANS, BECAUSE AS A RESULT OF THE CONTRACTOR'S OPERATIONS AND/OR THOSE OF HIS SUBCONTRACTORS, AND SHALL RESTORE THEM PROMPTLY TO THE ORIGINAL CONDITIONS OR BETTER AT NO ADDITIONAL EXPENSE TO THE OWNER. CONTRACTOR SHALL REPORT ANY DAMAGED SIDEWALK, DRIVEWAY, ETC., PRIOR TO BEGINNING WORK IN ANY AREA.

43. THE CONTRACTOR SHALL BE RESPONSIBLE FOR MAINTAINING THE INTEGRITY AND MAKING THE REPAIRS OF EXISTING PAVEMENT, SIDEWALKS, PIPES, CONDUITS, CURBS, CABLES, ETC. SHOWN ON THE PLANS, BECAUSE AS A RESULT OF THE CONTRACTOR'S OPERATIONS AND/OR THOSE OF HIS SUBCONTRACTORS, AND SHALL RESTORE THEM PROMPTLY TO THE ORIGINAL CONDITIONS OR BETTER AT NO ADDITIONAL EXPENSE TO THE OWNER. CONTRACTOR SHALL REPORT ANY DAMAGED SIDEWALK, DRIVEWAY, ETC., PRIOR TO BEGINNING WORK IN ANY AREA.

44. THE CONTRACTOR SHALL BE RESPONSIBLE FOR MAINTAINING THE INTEGRITY AND MAKING THE REPAIRS OF EXISTING PAVEMENT, SIDEWALKS, PIPES, CONDUITS, CURBS, CABLES, ETC. SHOWN ON THE PLANS, BECAUSE AS A RESULT OF THE CONTRACTOR'S OPERATIONS AND/OR THOSE OF HIS SUBCONTRACTORS, AND SHALL RESTORE THEM PROMPTLY TO THE ORIGINAL CONDITIONS OR BETTER AT NO ADDITIONAL EXPENSE TO THE OWNER. CONTRACTOR SHALL REPORT ANY DAMAGED SIDEWALK, DRIVEWAY, ETC., PRIOR TO BEGINNING WORK IN ANY AREA.

45. THE CONTRACTOR SHALL BE RESPONSIBLE FOR MAINTAINING THE INTEGRITY AND MAKING THE REPAIRS OF EXISTING PAVEMENT, SIDEWALKS, PIPES, CONDUITS, CURBS, CABLES, ETC. SHOWN ON THE PLANS, BECAUSE AS A RESULT OF THE CONTRACTOR'S OPERATIONS AND/OR THOSE OF HIS SUBCONTRACTORS, AND SHALL RESTORE THEM PROMPTLY TO THE ORIGINAL CONDITIONS OR BETTER AT NO ADDITIONAL EXPENSE TO THE OWNER. CONTRACTOR SHALL REPORT ANY DAMAGED SIDEWALK, DRIVEWAY, ETC., PRIOR TO BEGINNING WORK IN ANY AREA.


46. THE CONTRACTOR SHALL BE RESPONSIBLE FOR MAINTAINING THE INTEGRITY AND MAKING THE REPAIRS OF EXISTING PAVEMENT, SIDEWALKS, PIPES, CONDUITS, CURBS, CABLES, ETC. SHOWN ON THE PLANS, BECAUSE AS A RESULT OF THE CONTRACTOR'S OPERATIONS AND/OR THOSE OF HIS SUBCONTRACTORS, AND SHALL RESTORE THEM PROMPTLY TO THE ORIGINAL CONDITIONS OR BETTER AT NO ADDITIONAL EXPENSE TO THE OWNER. CONTRACTOR SHALL REPORT ANY DAMAGED SIDEWALK, DRIVEWAY, ETC., PRIOR TO BEGINNING WORK IN ANY AREA.

47. THE CONTRACTOR SHALL BE RESPONSIBLE FOR MAINTAINING THE INTEGRITY AND MAKING THE REPAIRS OF EXISTING PAVEMENT, SIDEWALKS, PIPES, CONDUITS, CURBS, CABLES, ETC. SHOWN ON THE PLANS, BECAUSE AS A RESULT OF THE CONTRACTOR'S OPERATIONS AND/OR THOSE OF HIS SUBCONTRACTORS, AND SHALL RESTORE THEM PROMPTLY TO THE ORIGINAL CONDITIONS OR BETTER AT NO ADDITIONAL EXPENSE TO THE OWNER. CONTRACTOR SHALL REPORT ANY DAMAGED SIDEWALK, DRIVEWAY, ETC., PRIOR TO BEGINNING WORK IN ANY AREA.

48. THE CONTRACTOR SHALL BE RESPONSIBLE FOR MAINTAINING THE INTEGRITY AND MAKING THE REPAIRS OF EXISTING PAVEMENT, SIDEWALKS, PIPES, CONDUITS, CURBS, CABLES, ETC. SHOWN ON THE PLANS, BECAUSE AS A RESULT OF THE CONTRACTOR'S OPERATIONS AND/OR THOSE OF HIS SUBCONTRACTORS, AND SHALL RESTORE THEM PROMPTLY TO THE ORIGINAL CONDITIONS OR BETTER AT NO ADDITIONAL EXPENSE TO THE OWNER. CONTRACTOR SHALL REPORT ANY DAMAGED SIDEWALK, DRIVEWAY, ETC., PRIOR TO BEGINNING WORK IN ANY AREA.

49. THE CONTRACTOR SHALL BE RESPONSIBLE FOR MAINTAINING THE INTEGRITY AND MAKING THE REPAIRS OF EXISTING PAVEMENT, SIDEWALKS, PIPES, CONDUITS, CURBS, CABLES, ETC. SHOWN ON THE PLANS, BECAUSE AS A RESULT OF THE CONTRACTOR'S OPERATIONS AND/OR THOSE OF HIS SUBCONTRACTORS, AND SHALL RESTORE THEM PROMPTLY TO THE ORIGINAL CONDITIONS OR BETTER AT NO ADDITIONAL EXPENSE TO THE OWNER. CONTRACTOR SHALL REPORT ANY DAMAGED SIDEWALK, DRIVEWAY, ETC., PRIOR TO BEGINNING WORK IN ANY AREA.

50. THE CONTRACTOR SHALL BE RESPONS

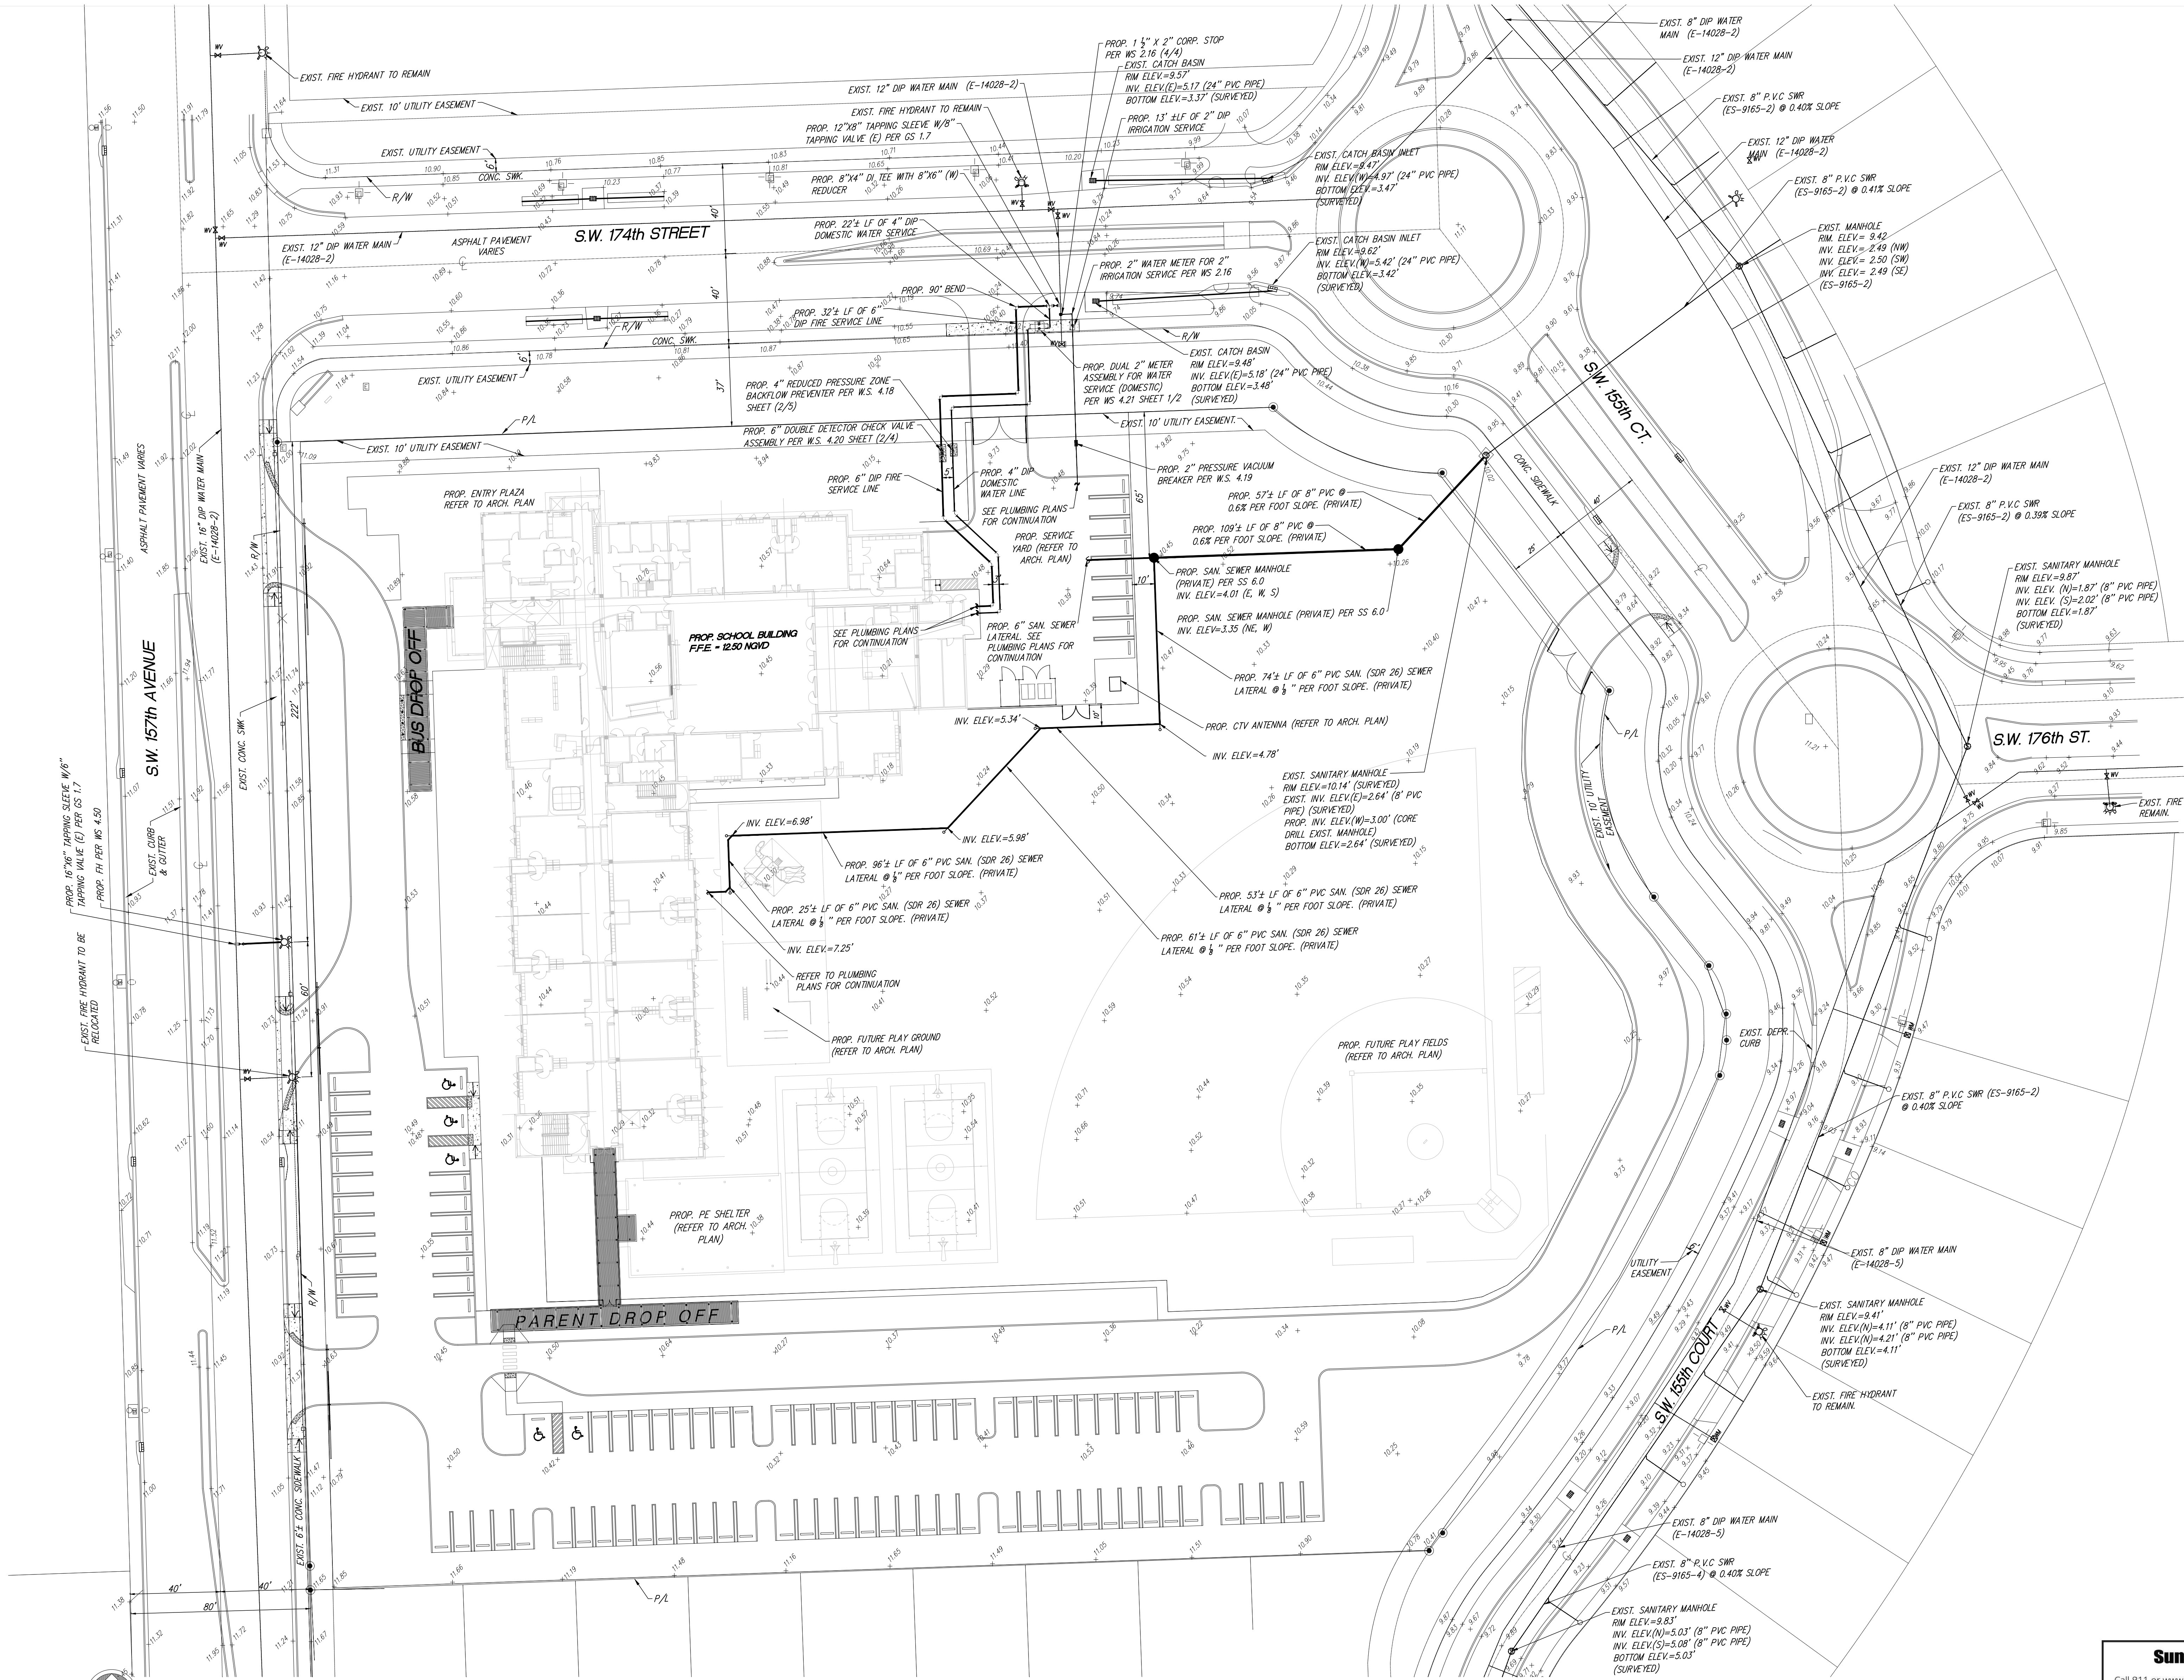

WATER AND SEWER PLAN

SCALE: 1" = 30'


CONSULTANT INFO:



VENETIAN PARC WEST K-5 SCHOOL

SOUTHWEST 157th AVENUE and 174th STREET
MIAMI, FL. 33187
MDCPS PROJECT No. 01892600

KEY PLAN

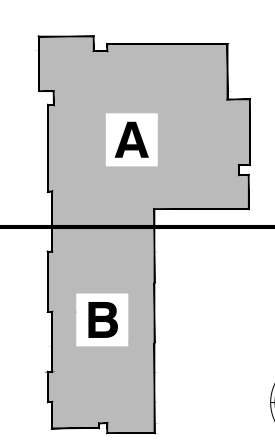

CONSULTANT INFO:

Jorge R. Avinó
PE No. 22207

RODRIGUEZ ARCHITECTS INCORPORATED
2121 PONCE DE LEON BLVD. STE. 1010
CORAL GABLES, FL. 33134
TEL: (305) 448-3373
FAX: (305) 448-3374

RAI

REVISIONS:

NO.	DATE	DESCRIPTION
02.14.20	BCC COMMENTS	

DRAWING TITLE:

WATER & SEWER PLAN

SCALE: AS NOTED

ISSUE DATE: 12.16.19 PROJECT NO. 1906




SHEET: WS-2

ENGINEER'S CERTIFICATION:


I HEREBY CERTIFY: That this plan was prepared under my direction and to the best of my knowledge and belief complies with the intent of the "MANUAL OF UNIFORM STANDARDS FOR DESIGN, CONSTRUCTION AND MAINTENANCE FOR STREETS, AND HIGHWAYS", as adopted by the State of Florida Legislature, Chapter 72-328 F.S.



Call 811 or www.sunshine811.com two full business days before digging to have utilities located and marked.
Check positive response codes before you dig!

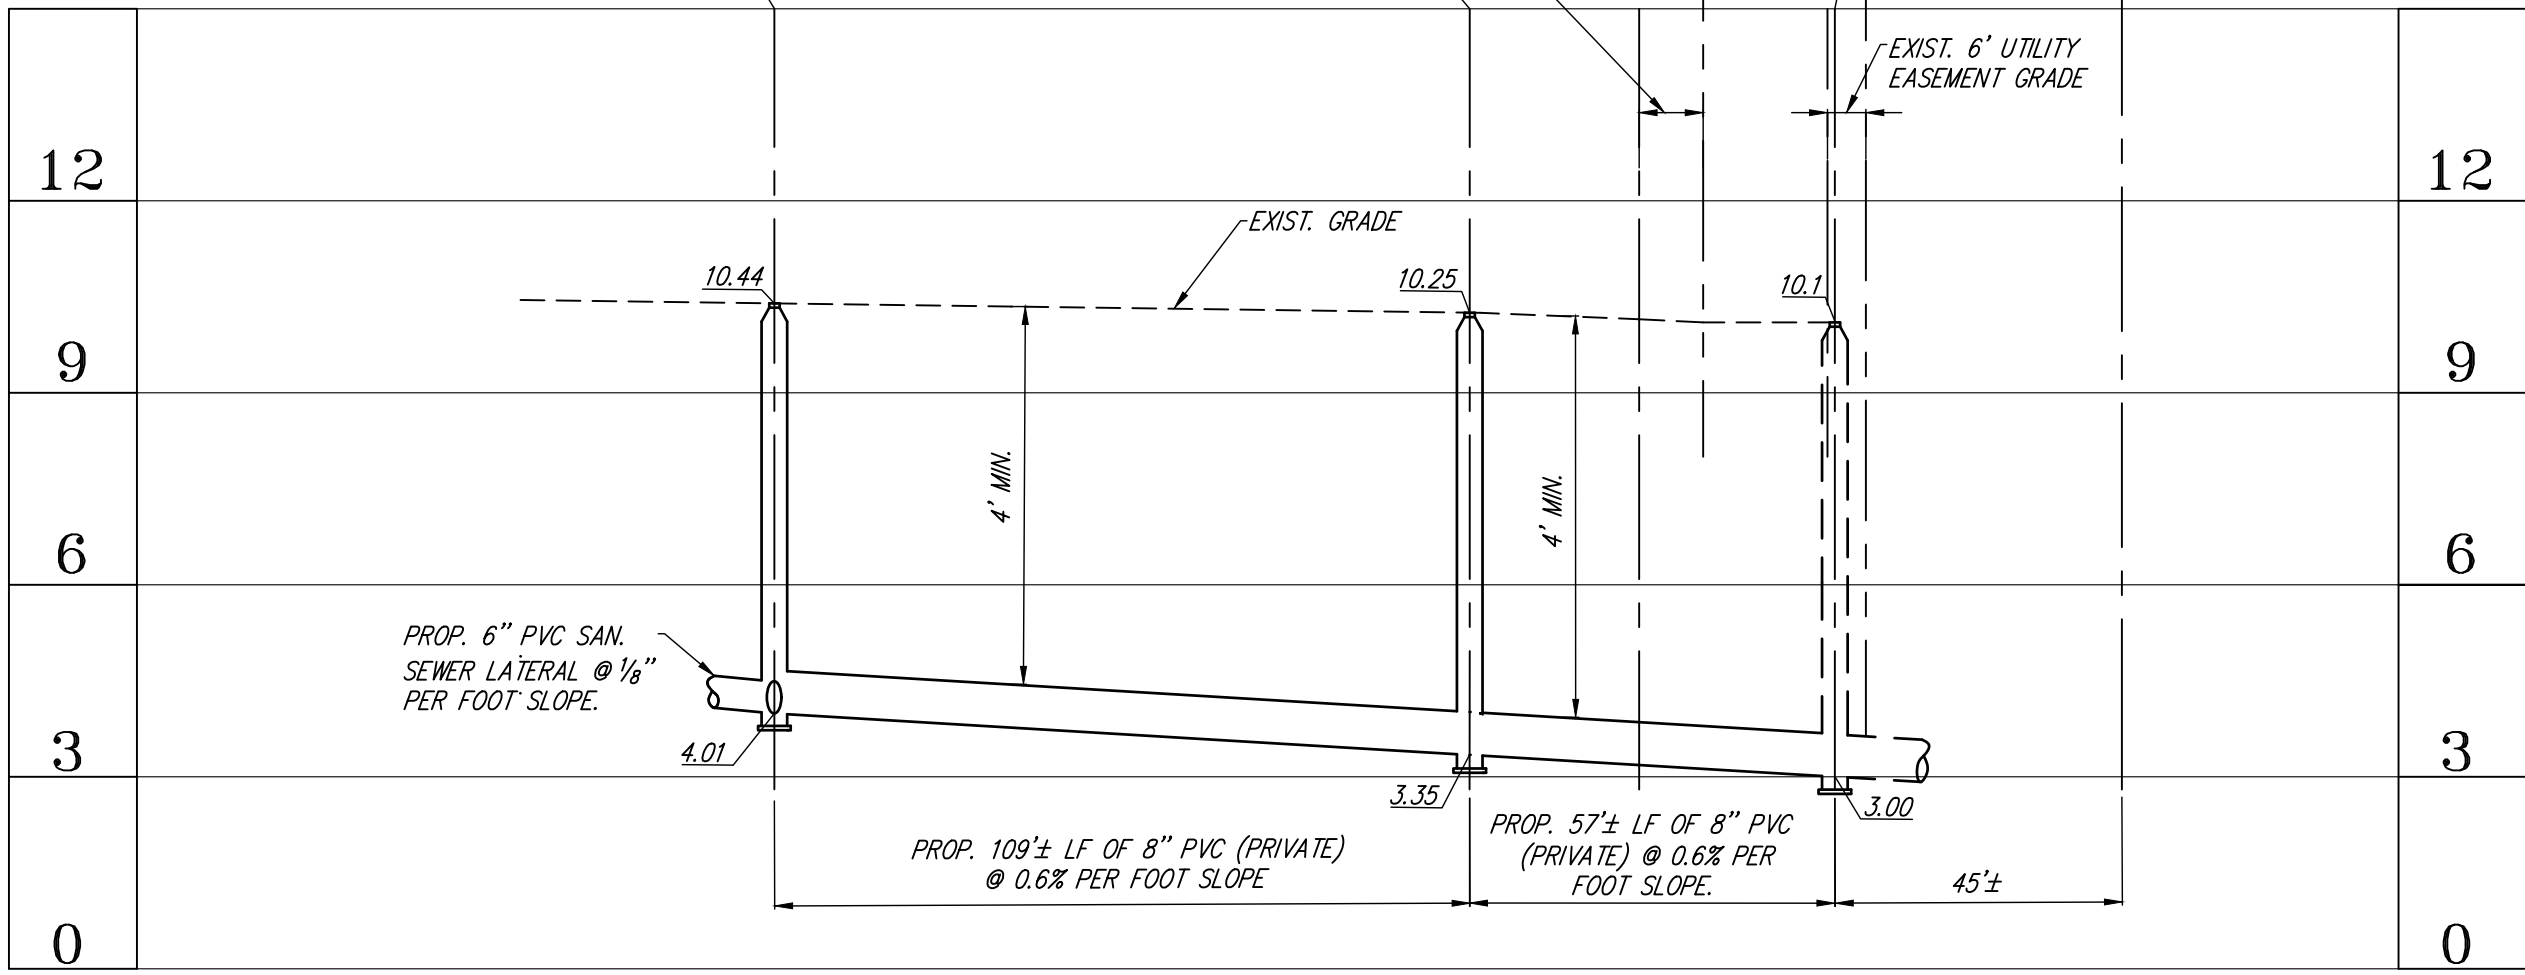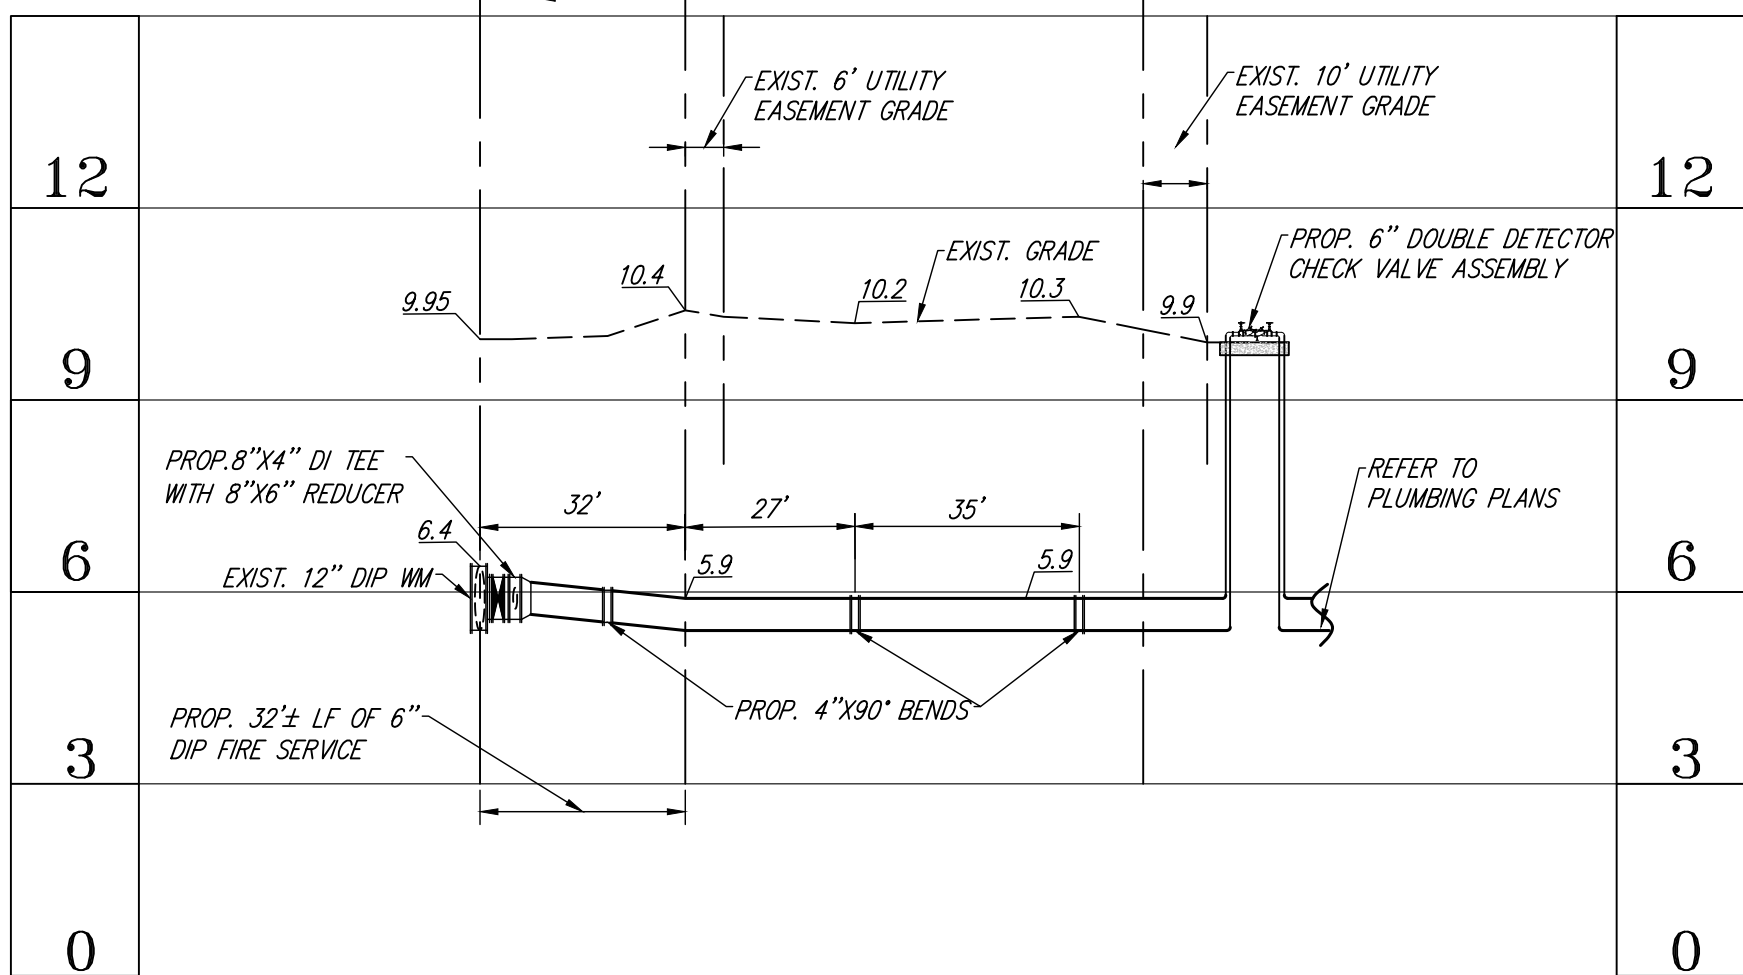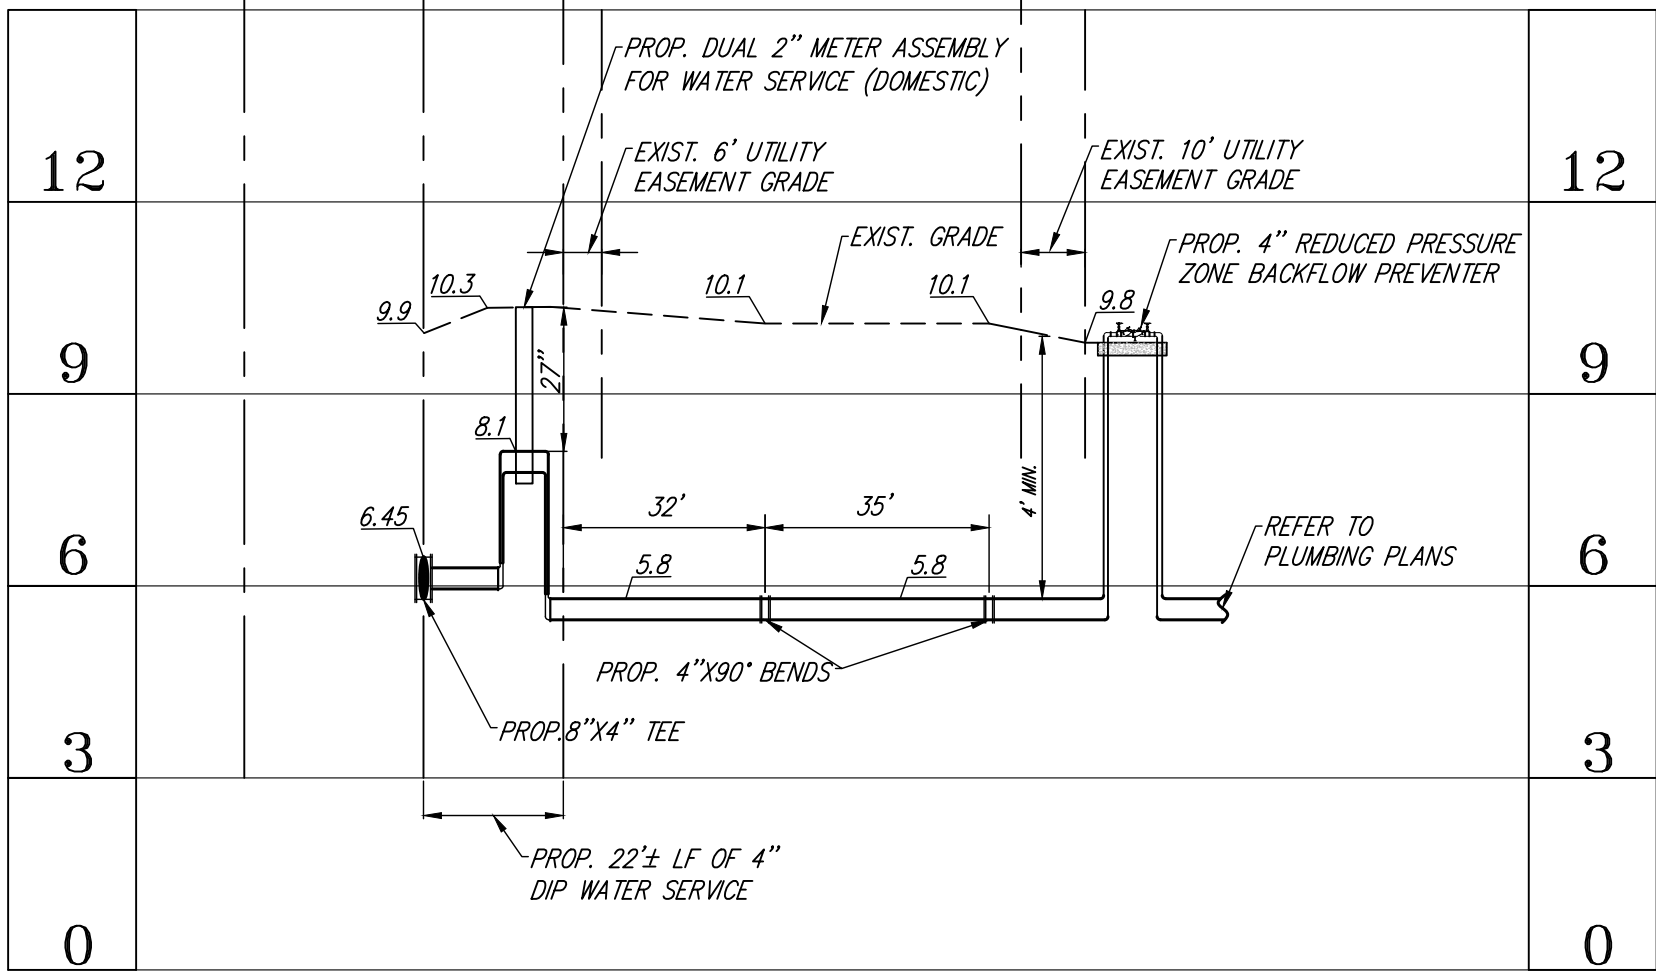


WATER AND SEWER PROFILES
SCALE: AS SHOWN

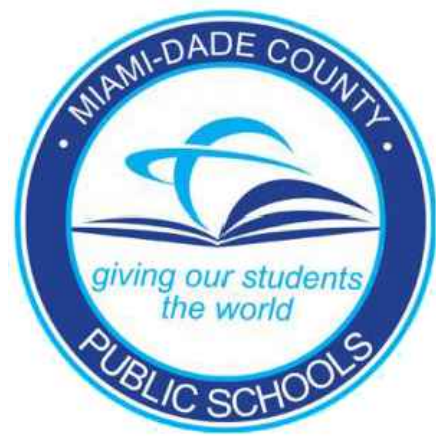

VENETIAN PARC WEST K-5
SCHOOL

SOUTHWEST 157th AVENUE and 174th STREET
MIAMI, FL. 33187
MDCPS PROJECT No. 01892600

KEY PLAN

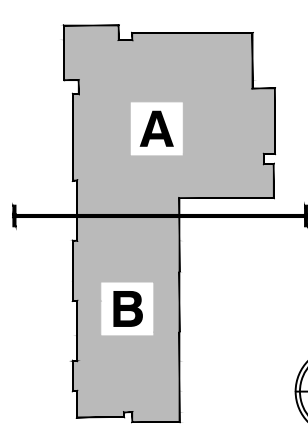

CONSULTANT INFO:

Jorge R. Aviñó
95 N. 99097

**RODRIGUEZ
ARCHITECTS
INCORPORATED**
2121 PONCE DE LEON BLVD. STE. 1010
CORAL GABLES, FL. 33134
TEL: (305) 448-3373
FAX: (305) 448-3374

A A C -- 0 0 1 9 3 3

REVISIONS:

ENGINEER'S CERTIFICATION:

I HEREBY CERTIFY: That this plan was prepared under my direction and to the best of my knowledge and belief complies with the intent of the "MANUAL OF UNIFORM STANDARDS FOR DESIGN, CONSTRUCTION AND MAINTENANCE FOR STREETS, AND HIGHWAYS", as adopted by the State of Florida Legislature, Chapter 72-328 F.S.

AWING TITLE

WATER & SEWER PROFILES

ALL AS NOTED

DUPLICATE DATE:

PROJECT NO.
10000

2.16.19
EET:



NS-3

1. Last day of field work was performed on April 10th, 2019.
2. Avino & Associates, Inc. and certifying Land Surveyor accept no responsibility for Rights-of-Way Easements, Restrictions of Record or other matters affecting title to lands surveyed other than those recited in current Deed and/or other instruments of record furnished by Client.
3. Bearings shown hereon are based on the West Line of NW 1/4 of Section 33-55S-39 as recorded in Section Map of Miami-Dade County, Florida with an assumed Bearing of N01° 40'01"W, said line to be considered a well monumented line.
4. By scaled determination the subject property appears to lie in Flood Zone X, Elevation N/A, as per Federal Emergency Management Agency (FEMA) Community-Panel Number 120634, Map No. 12086C0580, Suffix L, Revised Date: 09-11-2009. An accurate Zoned determination should be made by the preparer of the map, the Federal Emergency Management Agency, or the Local Government Agency having jurisdiction over such matters prior to any judgments being made from the Zone as noted. The referenced Federal Emergency Management Agency Map states in the notes to the user that "this map is for insurance purposes only".
5. The Survey depicted herein is not intended to show the location or existence of any Wetland or Jurisdictional areas, or areas of protected species of vegetation either natural or cultivated.
6. Any use of this Survey for purposes other than which it was intended, without written verification, will be the user's sole risk and without liability to the surveyor. Nothing herein shall be construed to give any rights or benefits to anyone than those certified to.
7. Vertical Control: Field-measured control for elevation information shown upon survey maps or reports shall be based on a level loop or closure to a second benchmark. Closure in feet must be accurate to a standard of plus or minus 0.05 ft. times the square root of the distance in miles. All surveys and maps or reports with elevation data shall indicate the datum and a description of the benchmark(s) upon which the survey is based. Minor elevation data may be obtained on an assumed datum provided the base elevation of the datum is obviously different than the established datum.
8. Horizontal Control: The minimum relative distance accuracy for this type of Survey is 1 foot in 10,000 feet. The accuracy obtained by measurement and calculation of closed geometric figures was found to exceed this requirement. Well-identified features as depicted on the Survey Map were measured to an estimated horizontal positional accuracy of 1/10 foot.
9. Since no other information other than what is cited in the Sources of Data were furnished, the Client is hereby advised that there may legal restrictions on the Subject Property that are not shown on the Survey Map or contained within this Report that may be found in the Public Records of Miami-Dade County, or the records of any other public and private entities as their jurisdictions may appear. The Surveyor makes no representation as to ownership or possession of the Subject Property by any entity or individual who may appear of public record.
10. Fence ownership not determined.
11. Legal descriptions provided by client or attesting title company.
12. Boundary survey means a drawing and/ or a graphic representation of the survey work performed in the field, could be drawn at a shown scale and/or not to scale; the walls or fences may be exaggerated for clarity purposes.

This notice is required by the "Standards of Practice for Land Surveying in the State of Florida," pursuant to Chapter 5J-17, Florida Administrative Code and as adopted by the Florida Board of Professional Surveyors and Mappers pursuant to Chapter 472, Florida Statutes.

Asph.	Asphalt	1-15-5	DBH=Height-Spread
℄	Center Line	DBH	Diameter @ Breast Height
CONC.	Concrete	U.E.	Utility Easement
CLF	Chain Link Fence	Swk.	Sidewalk
SQ.	Square	Δ	Central Angle
EB	Electric Box	L	Curve Length
ELEV.	Elevation	R	Curve Radius
F.I.P.	Find Iron Pipe		Concrete
FH	Fire Hydrant		Metal Cover
O.R.B.	Official Record Book	— X — X —	Chain Link Fence
P.B.	Plat Book	-----	Right of Way Lines
PG.	Page	CLP	Concrete Light Pole
℄	Property Line	MLP	Metal Light Pole
R/W	Right-of-Way	WPP	Utility Wood Power Pole
(C)	Calculated	CPP	Concrete Power Pole
(R)	Recorded		Water Valve
(M)	Measured		Water Meter
x 10.00	Spot Elevation		Fire Hydrant
	Palm (No Identified)		Electric Wiring Box
	Tree (No Identified)		

TREE TABLE				
#	NAME	DHB (FT)	HEIGHT (FT)	SPREAD (FT)
1	TREE	0.40	12	5
2	PALM	1.50	25	13
3 to 5	TREE	0.30	15	5
6 & 7	TREE	0.50	15	5
8 & 9	PALM	1.50	25	12
10 to 15	TREE	0.30	15	5
16 to 18a	PALM	1.50	25	12
19 to 21	TREE	0.50	15	5
22 to 24	TREE	0.30	15	5
25 & 26	TREE	0.50	15	5
27 to 29	TREE	0.30	15	5
30	PALM	1.50	25	12
31 to 34	TREE	0.30	15	5
35 & 36	TREE	0.50	15	5
37	PALM	1.50	25	12
38 to 45	TREE	0.30	15	5
46 to 50	TREE	0.30	15	5
51 to 53	PALM	1.50	25	12
54 & 55	PALM	2	5	12
56 & 57	TREE	0.40	13	6
58 to 62	PALM	2	20	12
63	PALM	2	5	12
64	TREE	0.40	13	6
65 to 72	PALM	2	25	12
73 to 75	TREE	0.40	12	4
76 to 79	PALM	1.5	18	8
80 to 82	TREE	0.40	15	6
83	TREE	1	20	10
84	TREE	1.50	18	8
85	TREE	0.40	15	6
86	PALM	1.5	18	8
87 & 89	PALM	2	25	16
90 to 94	TREE	0.40	15	6
95 to 97	PALM	2	25	16
98 to 100	TREE	0.40	15	6
101 to 119	TREE	0.40	15	6

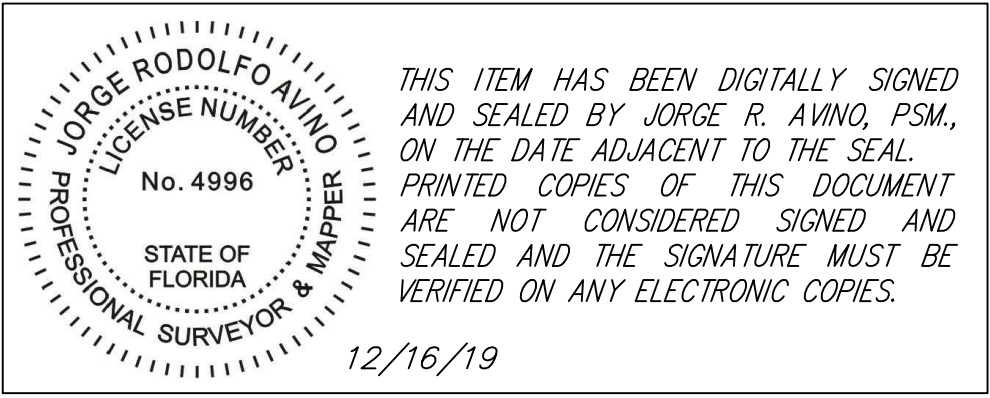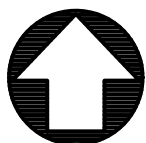

Tract "Q" of Venetian Parc West, according to the Plat thereof, as recorded in Plat Book 170, Page 27, of the Public Records of Miami-Dade County, Florida, formerly described as:

COMMENCE at the West 1/4 corner of said Section 33; thence N87°59'15"E along the South line of the Northwest 1/4 of said Section 33, for a distance of 40.00 feet to the POINT OF BEGINNING of the hereinafter described Parcel of Land; thence N01°40'01"W, along a line 40 feet East and parallel with the West line of the Northwest 1/4 of said Section 33, for a distance of 499.39 feet; thence N87°59'15"E for a distance of 442.70 feet to the intersection with the arch of a circular curve to the left, concave to the Northeast, a radial line from said point bears N43°03'46"E; thence Southeasterly and Easterly along the arch of said curve, having for its elements a radius of 108.13 feet, through a central angle of 43°39'17" for an arc distance of 82.54 feet to a point on a non-tangential line; thence S37°27'58"E for a distance of 121.94 feet to the intersection with the arc of a circular curve to the left, concave to the Northeast, a radial line from said point bears S75°42'59"E; thence Southeasterly along the arc of said curve, having for its elements a radius of 105.00 feet, through a central angle of 52°59'28" for an arc distance of 97.11 feet to a point of tangency; thence S38°42'26"E for a distance of 39.12 feet to a point of curvature of a circular curve to the right, concave to the Southwest; thence Southeasterly and Southerly along the arc of said curve, having for its elements a radius of 35.00 feet, through a central angle of 38°02'31" for an arc distance of 23.24 feet to a point of tangency; thence S00°39'55"E for a distance of 11.66 feet to a point of curvature of a circular curve to the right, concave to the Northwest; thence Southerly and Southwesterly along the arc of said curve, having for its elements a radius of 40.00 feet, through a central angle of 22°59'29" for an arc distance of 16.05 feet to a point of compound curvature of a circular curve to the right, concave to the Northwest; thence Southwesterly along the arc of said curve, having for its elements a radius of 769.80 feet, through a central angle of 17°45'15" for an arc distance of 238.54 feet to a point of reverse curvature of a circular curve to the left, concave to the Southeast; thence Southwesterly along the arc of said curve, having for its elements a radius of 100.00 feet, through a central angle of 5°41'42" for an arc distance of 9.94 feet to a point on a line 10.73 feet South of and parallel with the South line of the Northwest 1/4 of said Section 33; thence S87°59'15"W along the last described line for a distance of 497.24 feet to a point on a line 40.00 feet East of and parallel with the West line of said Section 33; thence N01°16'16"W, along the last described line for a distance of 10.73 feet to the POINT OF BEGINNING.

Folio No. 30-5933-035-4090

MIAMI-DADE COUNTY PUBLIC WORKS DEPT. BENCHMARK USED		
BENCHMARK	DESCRIPTION	ELEVATION
G-11	SW 176th Street --- On Centerline. SW 157th Avenue --- On Centerline.	11.89'
BC-40	3/4" Iron Pipe in Square cut of Asphalt	11.35'
	SW 168th Street --- 31.7' South of Centerline. SW 157th Avenue --- 37' East of Centerline. 54.2' SE of NW Corner of Section 33-55-39	
	BRASS BAR in Concrete Monument	

ELEVATIONS AS SHOWN HEREON REFER TO THE NATIONAL GEODETIC VERTICAL DATUM OF 1929 (NGVD 1929).

NOTICE: Not valid without the signature and original raised seal of a Florida Licensed Surveyor and Mapper. Additions or deletions to Survey Maps by other than the signing party are prohibited without the written consent of the signing party.

Project Name:

**VENETIAN
PARC
WEST K-5
SCHOOL**

**S.W. 157th AVE &
S.W. 174th STREET
MIAMI, FL, 33187**

Property Owner:

*SCHOOL
BOARD OF
MIAMI-DADE
COUNTY*

[illegible]

BOUNDARY
AND
TOPOGRAPHIC
SURVEY

LAND SURVEYOR & MAPPER

Jorge R. Aviffo, PSM No. 4996
Land Surveyor & Mapper

504

Sheet No. 1 OF 2

Project Name:

**VENETIAN
PARC
WEST K-5
SCHOOL**

**S.W. 157th AVE &
S.W. 174th STREET
MIAMI, FL, 33187**

Property Owner:

SCHOOL
BOARD OF
MIAMI-DADE
COUNTY

Revisions

[illegible]

WRITTEN DIMENSIONS ON THIS DRAWING SHALL
TAKE PRECEDENCE OVER SCALED DIMENSIONS.
THE CONTRACTOR SHALL VERIFY AND BE RESPONSIBLE
FOR ALL DIMENSIONS AND CONDITIONS ON THE
JOB AND THIS OFFICE MUST BE NOTIFIED OF
ANY VARIATION FROM THE DIMENSIONS.

BOUNDARY
AND
TOPOGRAPHIC
SURVEY

LAND SURVEYOR & MAPPER

Jorge R. Aviñó, PSM No. 4996
Land Surveyor & Mapper

Project No. 19108.00

scale: AS SHOWN

Date: 11/20/2019

Drawn: A.B.

checked: J.R.A.

ubmittal:

ad File:

Drawing Title:

SU-2

Sheet No. 2 OF 2



GRAPHIC SCALE


0' 20' 40'

1" = 40'




THIS ITEM HAS BEEN DIGITALLY SIGNED
AND SEALED BY JORGE R. AVINO, PSM.,
ON THE DATE ADJACENT TO THE SEAL.
PRINTED COPIES OF THIS DOCUMENT
ARE NOT CONSIDERED SIGNED AND
SEALED AND THE SIGNATURE MUST BE
VERIFIED ON ANY ELECTRONIC COPIES.

12/16/19

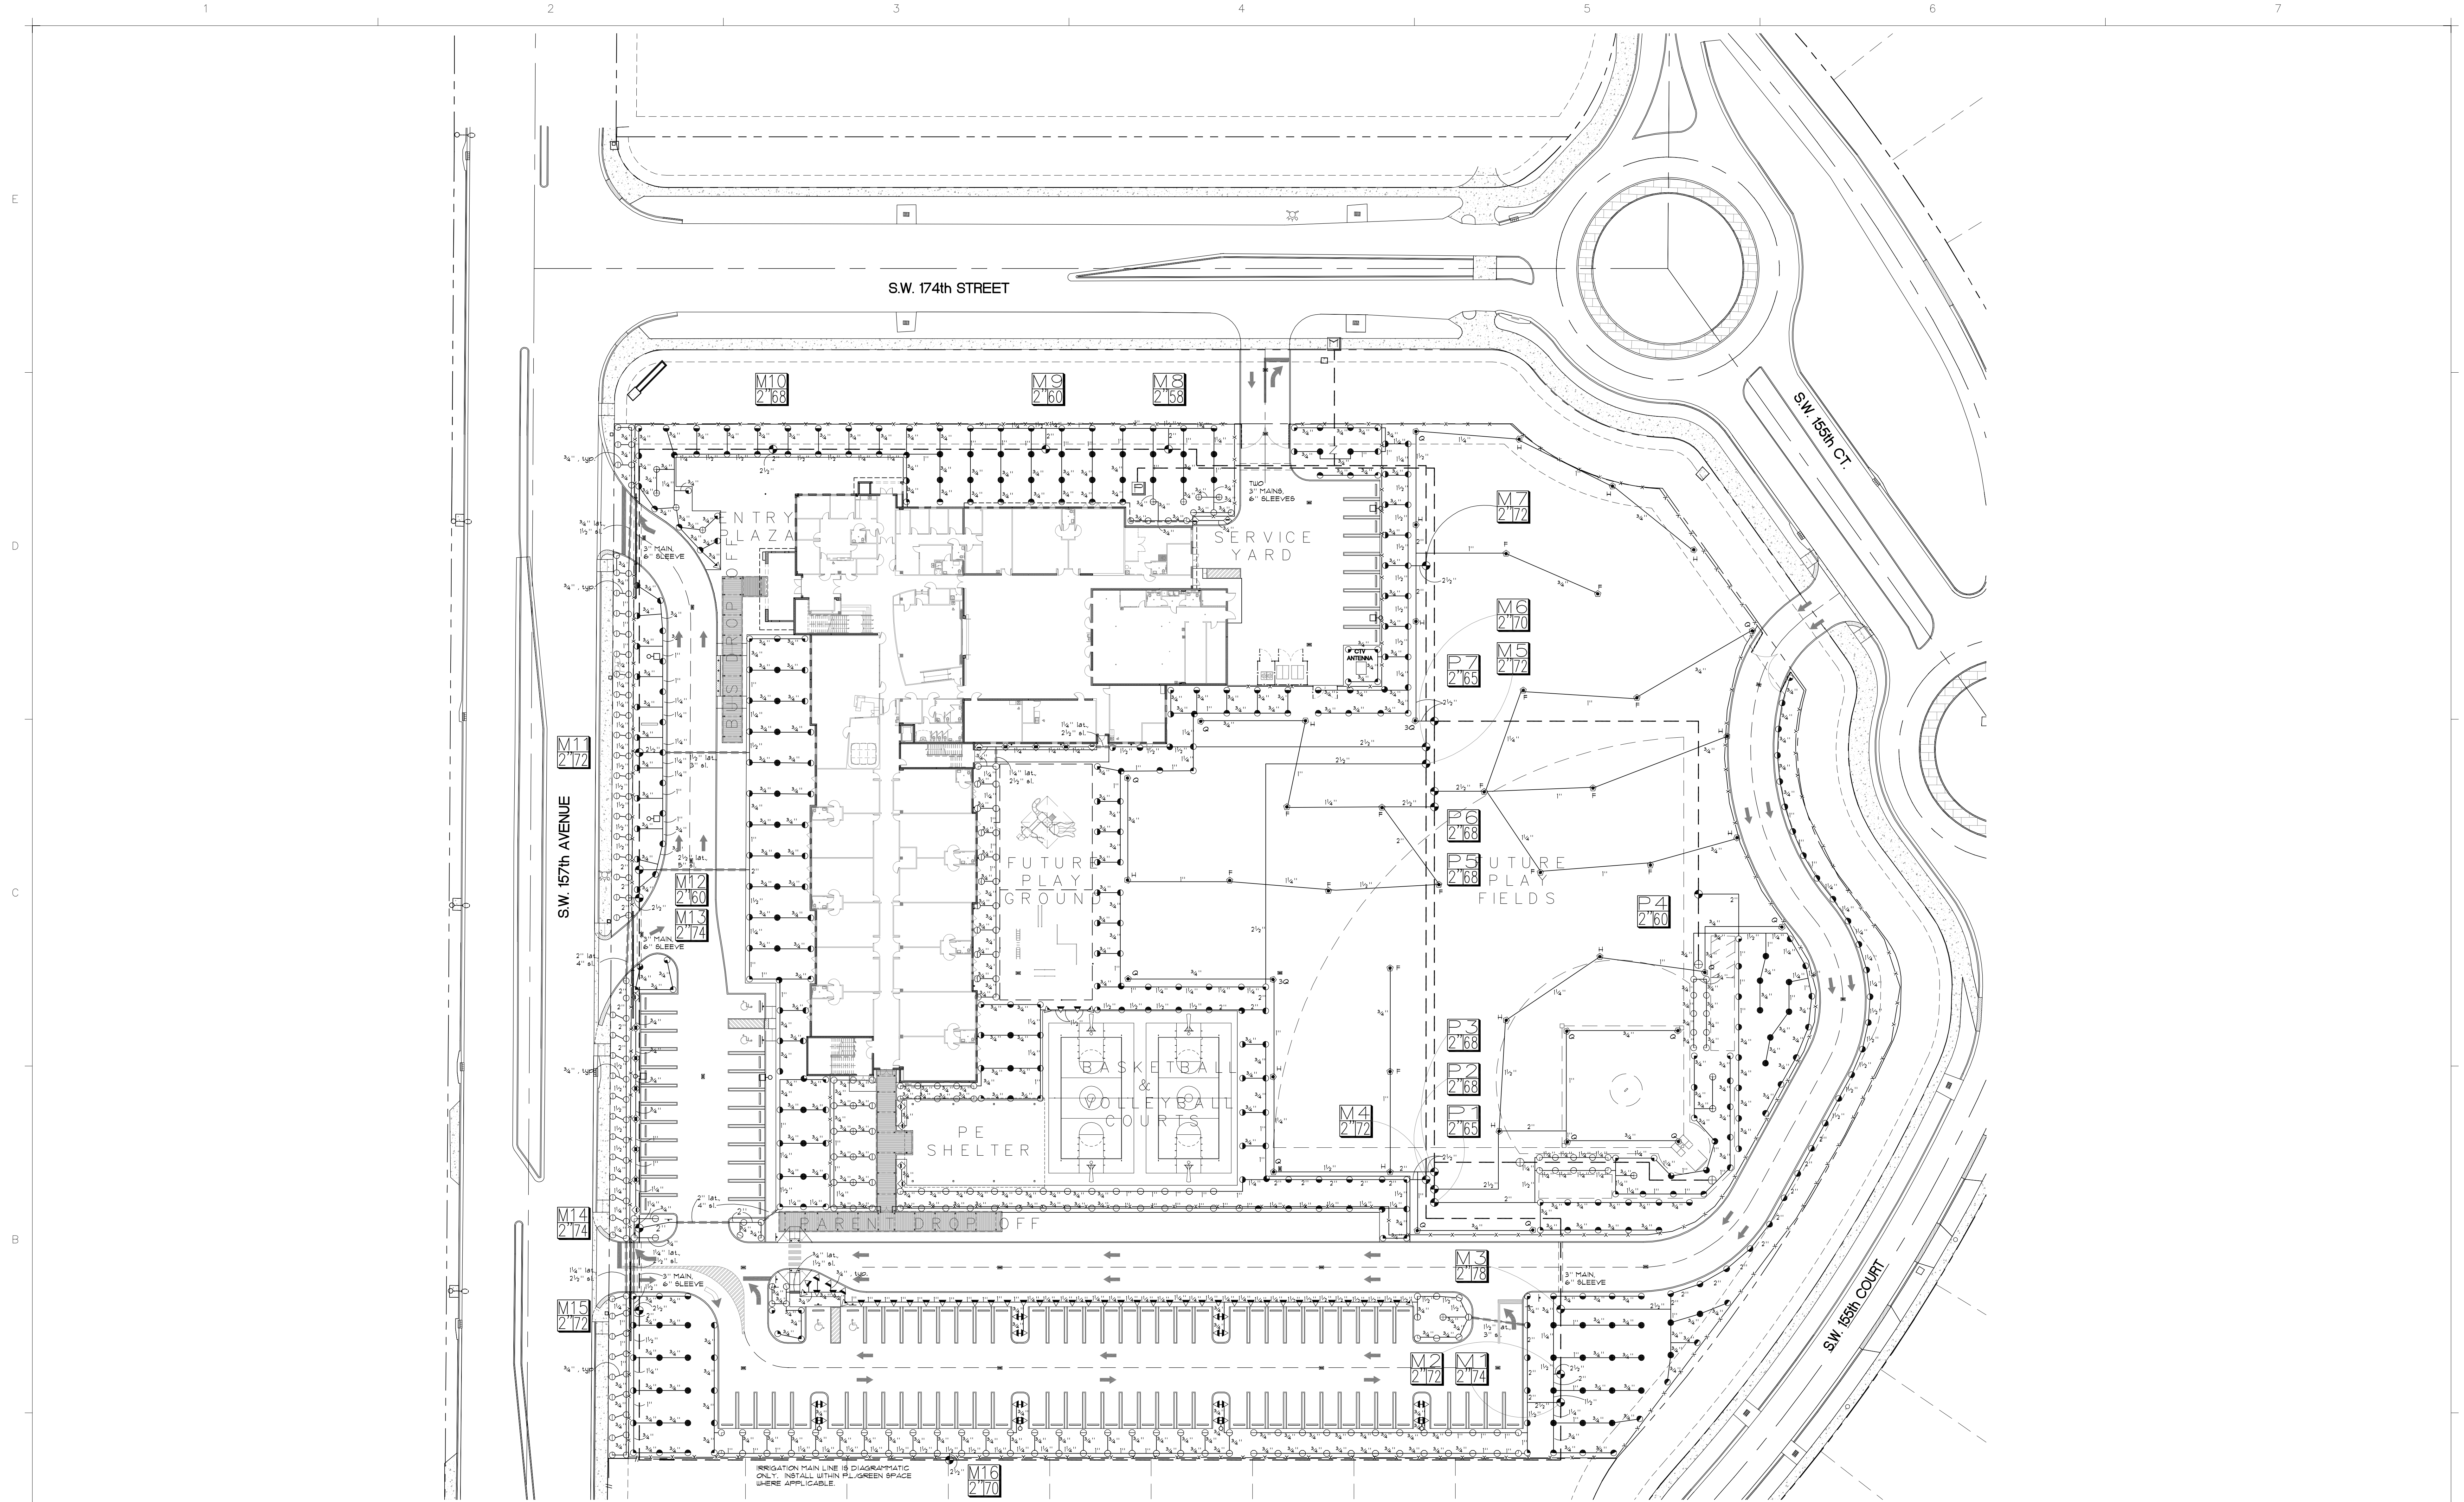

DRAWINGS AND SPECIFICATIONS AS INSTRUMENTS OF SERVICE ARE AND SHALL REMAIN THE PROPERTY OF THE LANDSCAPE ARCHITECT. WHENEVER THE PROJECT FOR WHICH THEY ARE MADE IS REPRODUCED OR NOT, THEY ARE NOT TO BE USED BY OWNER OR OTHER PROJECTS EXCEPT BY AGREEMENT IN WRITING AND WITH APPROPRIATE COMPENSATION TO THE LANDSCAPE ARCHITECT.

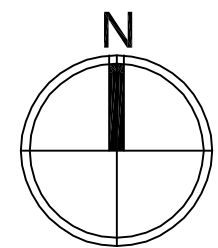

1 IRRIGATION PLAN
IR-100 Scale: 1"=30'-0"

CHECKED BY:
L.M.L.H.

DRAWN BY:
J.T.K.


CONSULTANT INFO:

DESIGNING BEAUTIFUL SPACES
LLA LAURA LLERENA & ASSOCIATES
LANDSCAPE ARCHITECTURE
13170 S.W. 128th Street, Suite 207, Miami, FL 33186
Tel: 305-256-1199 / Fax: 305-256-1155
www.llerena-associates.com




NEW ELEMENTARY SCHOOL (K-5)
VENETIAN PARC WEST
SOUTHWEST 157th AVENUE and 174th STREET
MIAMI, FL. 33187
MDCPS PROJECT No. 01892600

KEY PLAN

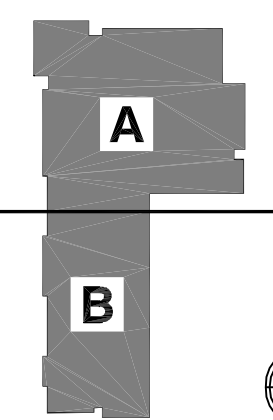

CONSULTANT INFO:

 

RODRIGUEZ ARCHITECTS INCORPORATED
2121 PONCE DE LEON BLVD., STE. 1010
CORAL GABLES, FL
TEL: (305) 448-3373
FAX: (305) 448-3374

AAC -- 001933

REVISIONS:


DRAWING TITLE:

IRRIGATION PLAN

SCALE AS NOTED

ISSUE DATE:
12.16.14
PROJECT NO.
1908
SHEET:
IR-100


R-101

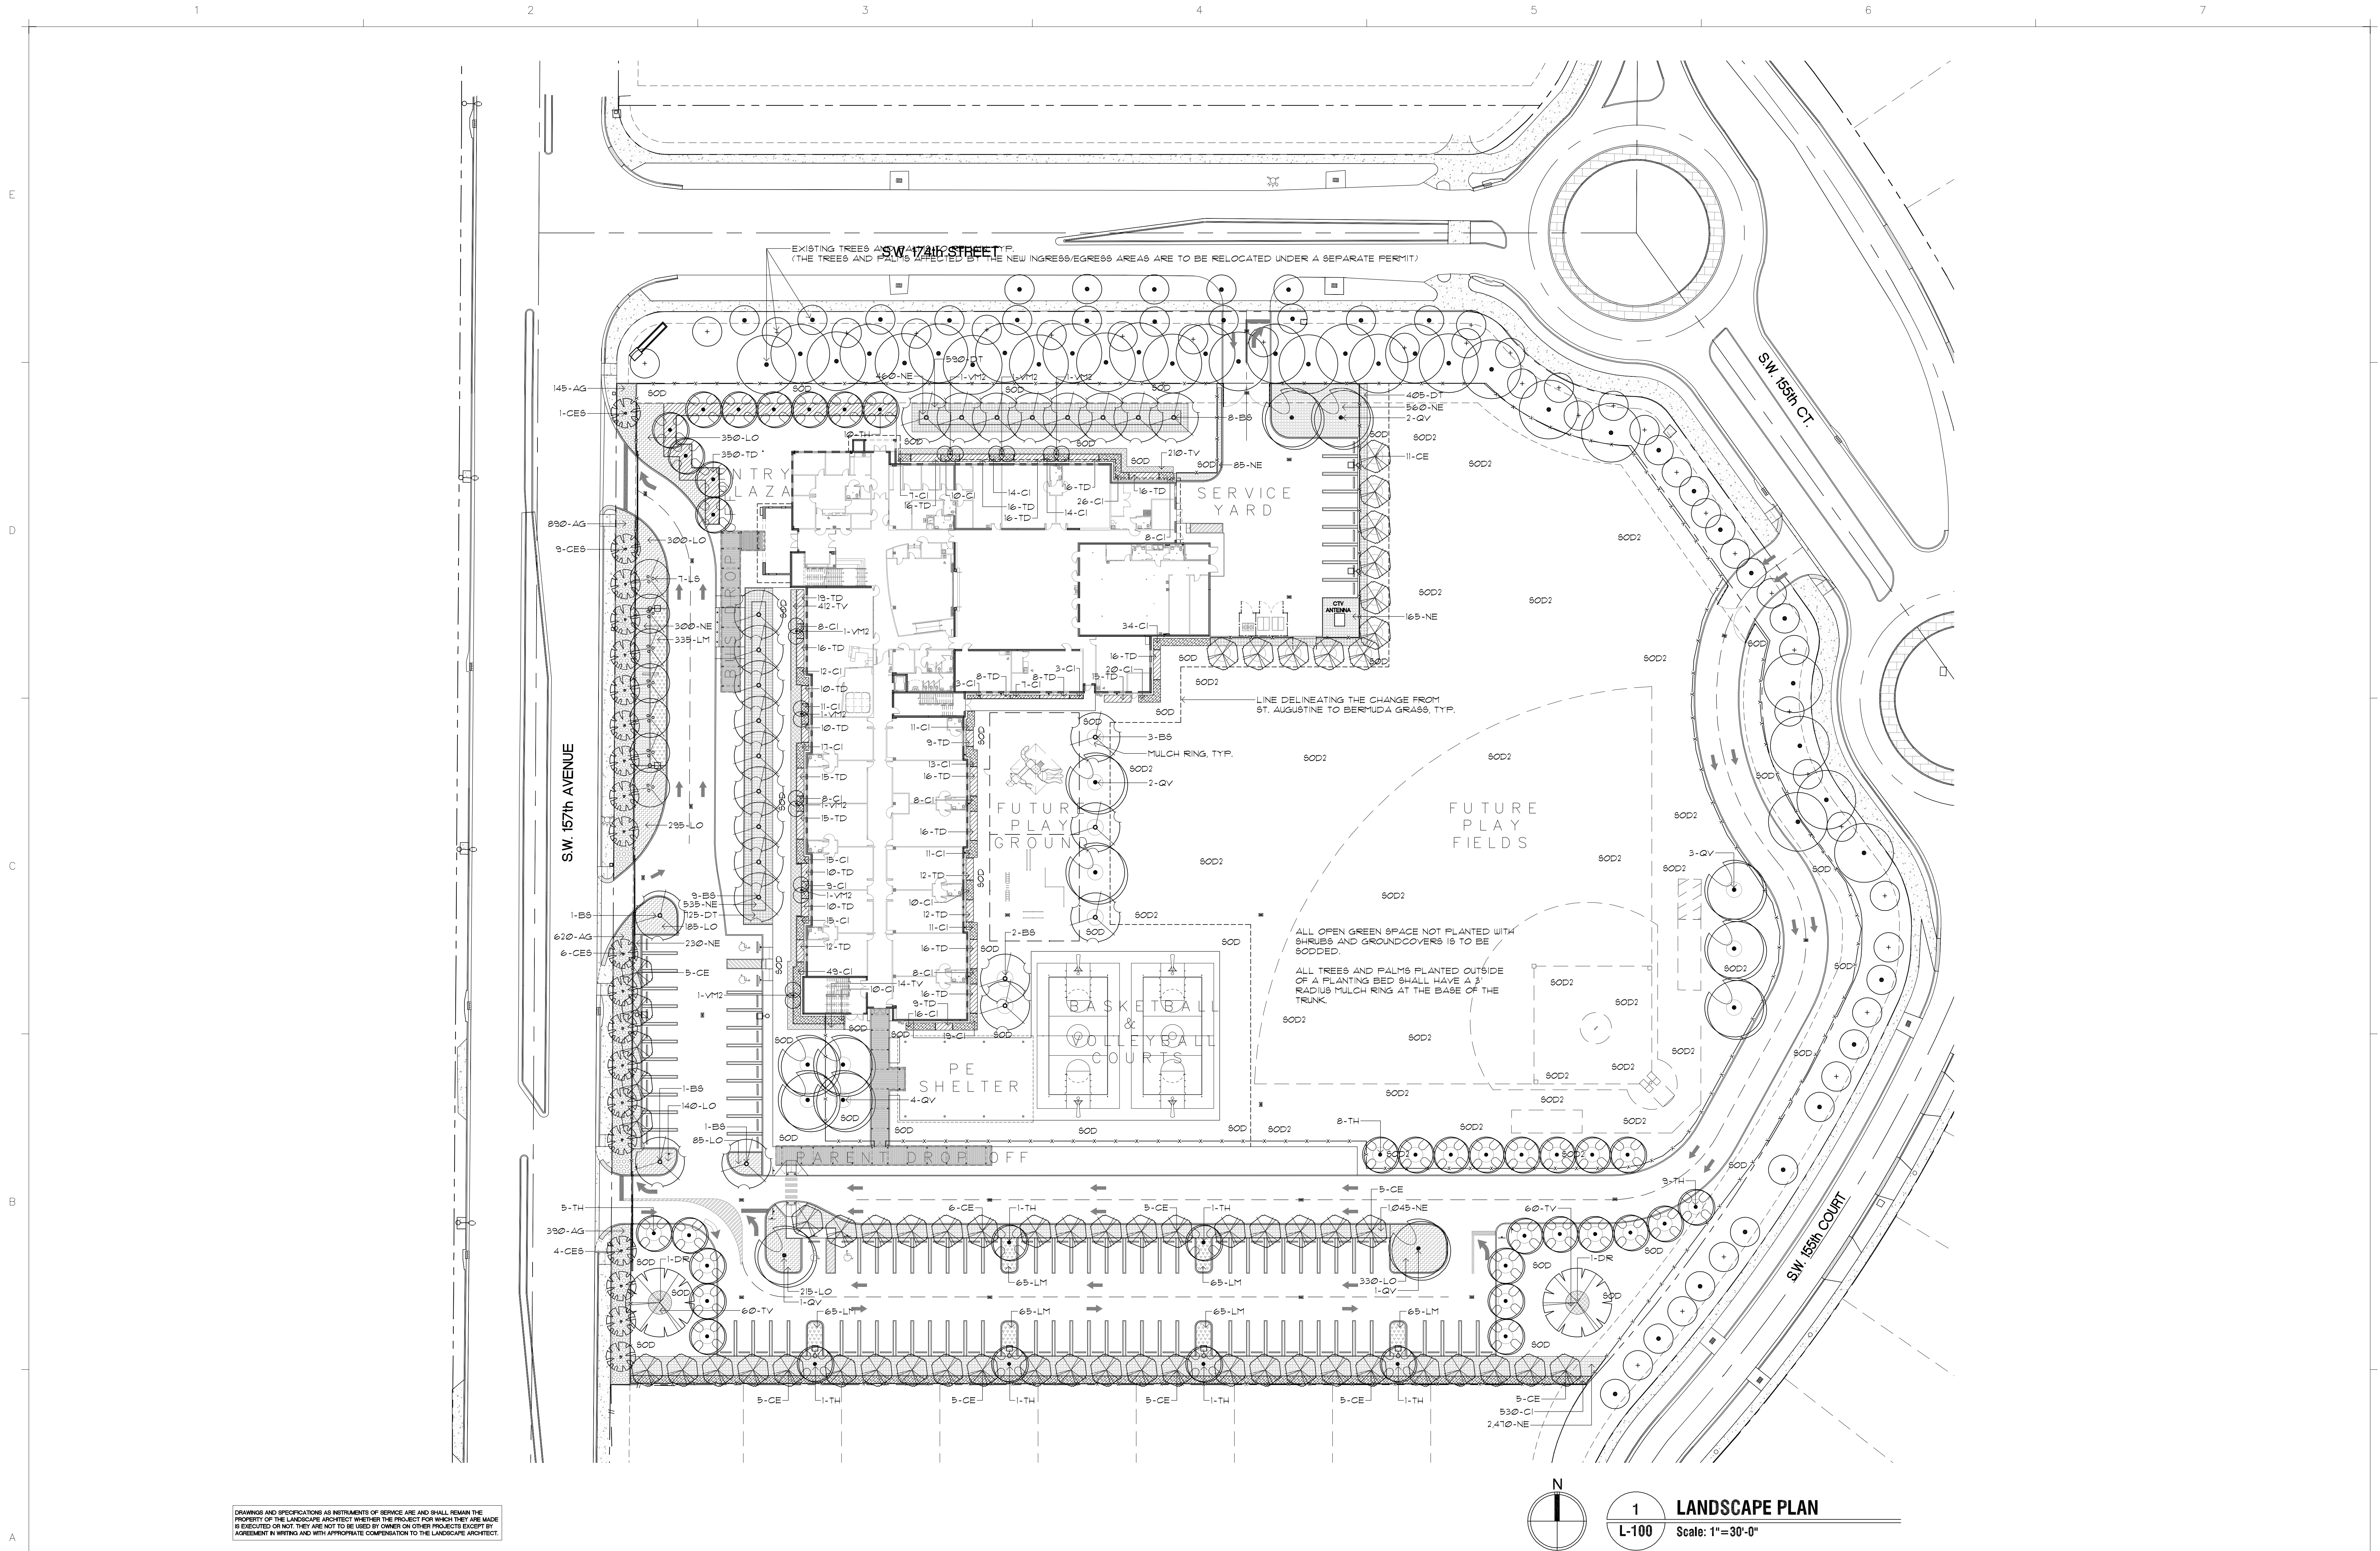

DRAWINGS AND SPECIFICATIONS AS INSTRUMENTS OF SERVICE ARE AND SHALL REMAIN THE PROPERTY OF THE LANDSCAPE ARCHITECT WHENEVER THE PROJECT FOR WHICH THEY ARE MADE IS EXECUTED OR NOT. THEY ARE NOT TO BE USED BY OWNER ON OTHER PROJECTS EXCEPT BY AGREEMENT IN WRITING AND WITH APPROPRIATE COMPENSATION TO THE LANDSCAPE ARCHITECT.


CONSULTANT INFO:

DESIGNING BEAUTIFUL SPACES
LLA LAURA LLERENA & ASSOCIATES
LANDSCAPE ARCHITECTURE
13170 S.W. 128th Street, Suite 207, Miami, FL 33186
Tel: 305-256-1199 / Fax: 305-256-1155
www.llerena-associates.com

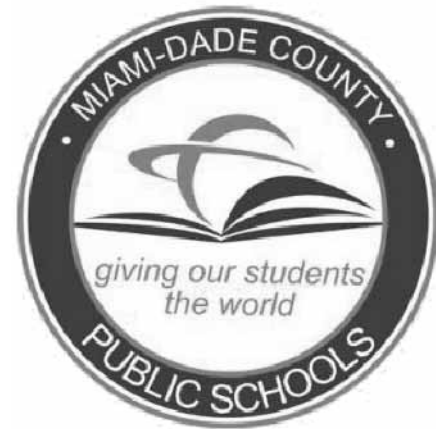

NEW ELEMENTARY SCHOOL (K-5)
VENETIAN PARC WEST
SOUTHWEST 157th AVENUE and 174th STREET
MIAMI, FL. 33187
MDCPS PROJECT No. 01892600

KEY PLAN

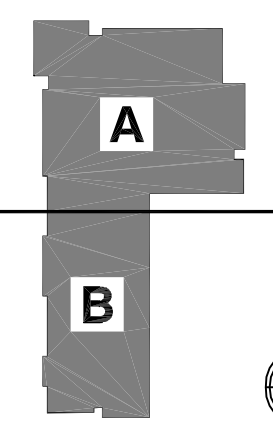

CONSULTANT INFO:



RODRIGUEZ ARCHITECTS INCORPORATED
2121 PONCE DE LEON BLVD., STE. 1010
CORAL GABLES, FL
TEL: (305) 448-3373
FAX: (305) 448-3374

REVISIONS:

DRAWING TITLE:

LANDSCAPE PLAN

SCALE AS NOTED

ISSUE DATE: 12.16.14
PROJECT NO. 1908
SHEET: L-100

PLANT LIST

QTY.	KEY	BOTANICAL NAME	COMMON NAME	TOLERANCE, SIZE & REMARKS
TREES:				
25	B5	BURSERA SIMARUBA	GUMBO LIMBO	Δ ** MIN 12' HT, MALE SPECIES ONLY, F.G.
61	CE	CONOCARPUS ERECTUS	GREEN BUTTWOOD	Δ ** MIN 20' HT, F.G.
20	CE5	CONOCARPUS E. 'SERICEUS'	SILVER BUTTWOOD	Δ ** MIN 12' HT, F.G. (SINGLE STEM)
2	DR	DELONIX REGIA	ROYAL PONCIANA	** MIN 25' HT, F.G. (SPECIMEN SIZE)
1	L5	LAGERSTROEMIA SPECIOSA	QUEEN'S GRAPE MYRTLE	Δ ** MIN 20' HT, F.G. (PURPLE FLOWERS)
13	QV	QUERCUS VIRGINIANA	LIVE OAK	Δ ** MIN 20' HT, F.G.
38	TH	TABEBUIA HETEROPHYLLA	PINK TRUMPET TREE	** MIN 15' HT, F.G.

PALMS:				
8	VM2	VEITCHIA MERRILLII	CHRISTMAS PALM (DOUBLE TRUNK)	** 12' OA HT, D.T., F.G.

SHRUBS:				
943	CI	CHRYSOBALANUS ICACO	RED TIP COCOPLUM	Δ ** 3 GAL., 24" O.C.
100	TD	TRIPSACUM DACTYLOIDES	FAKAHATCHEE GRASS	Δ ** 3 GAL., 24" O.C.

GROUNDCOVERS:				
2040	AG	ARACHIS GLABRATA	PERENNIAL PEANUT	Δ ** 1 GAL., 18" O.C., FULL, T.S.
1720	DT	DIANELLA T. 'VARIEGATA'	VARIEGATED FLAX LILY	** 1 GAL., 18" O.C., FULL, T.S.
725	LM	LANTANA MONTEVIDENSIS	TRAILING LANTANA	** 1 GAL., 18" O.C., FULL, T.S.
1300	LO	LANTANA O. 'RECLINATA'	DWARF LANTANA	Δ ** 1 GAL., 18" O.C., FULL, T.S.
5765	NE	NEPHROLEPIS EXALTATA	BOSTON FERN	Δ ** 1 GAL., 18" O.C., FULL, T.S.
756	TV	TULBAGHIA VIOLACEA	SOCIETY GARLIC	** 1 GAL., 18" O.C., FULL, T.S.

SOD:				
350004	SOD	STENOTAPHRUM SECUNDATUM	ST. AUGUSTINE FLORATAM	Δ * SOLID SOD
860004	SOD2	CYNODON DACTYLON	BERMUDA GRASS	Δ * SOLID SOD

ABBREVIATIONS:				DROUGHT TOLERANCE & ORIGIN:
OA. HT.	OVERALL HEIGHT	MIN.	MINIMUM	* MODERATE DROUGHT TOLERANCE
STG.	STAGGERED	STD.	STANDARD	** VERY DROUGHT TOLERANT
S.R.	SINGLE ROW	O.C.	ON CENTER	Δ NATIVE
T.S.	TRIANGULAR SPACING	GAL.	GALLON	
S.T.	SINGLE TRUNK	GW.	GREY WOOD	
D.T.	DOUBLE TRUNK			

NEW TREE - 1 YEAR MAINTENANCE PLAN

WATER:
ALL NEW TREES TO BE ON A AUTOMATED IRRIGATION SYSTEM WITH RAIN SENSOR.
1ST MONTH WATER EVERYDAY
2ND, THROUGH 6TH MONTHS - EVERY OTHER DAY.
1TH THROUGH COMPLETE YEAR - 2 TIMES A WEEK.
NOTE: ADJUST IRRIGATION DURATION TIMES TO ENSURE THAT TREE'S ROOT BALL IS COMPLETELY SATURATED WITH WATER.
IRRIGATION WATER FREQUENCY AND DURATIONS MAY VARY DUE TO TIME OF YEAR AND CLIMATE CONDITIONS.

FERTILIZER:
USE A PALM SPECIAL FERTILIZER, 8-2-12, FROM ATLANTIC FERTILIZER, 1 LBS. PER INCH CALIPER OF TREE EVERY 3 MONTHS.







MULCH:
INSPECT AND REPLACE MULCH AFTER 6 MONTHS WITH APPROVED FLORMULCH, EUCALYPTUS OR MELALEUCA MULCH ONLY.
NO RED COLORED OR CYFPRESS MULCH TO BE USED.

TRIMMING & PRUNING:
PRUNE ONLY CRITICAL BRANCHES (DEAD OR BROKEN)

STAKING AND BRACING:
INSPECT ALL TREE TIES AND STAKING AND ADJUST AS NEEDED. REMOVE ANY STAKING MATERIAL THAT IS IN CONTACT WITH TREE AFTER A PERIOD OF NO MORE THAN 6 MONTHS AFTER INITIAL PLANTING AS THE TREE SHOULD BE WELL ESTABLISHED BY THEN.

LANDSCAPE NOTES

1. ALL PLANT MATERIAL SHALL BE GRADED FLORIDA * OR BETTER, AS DEFINED IN THE GRADES AND STANDARDS FOR NURSERY PLANTS, PART I AND II BY THE STATE OF FLORIDA, DEPARTMENT OF AGRICULTURE.
2. ALL LANDSCAPE MATERIAL SHALL COMPLY WITH COUNTY, CITY OR LOCAL ORDINANCES.
3. SYMBOLS REPRESENT PLANTS AT MATURE STAGE, NEVER AT TIME OF INSTALLATION.
4. VERIFY WITH OWNER'S REPRESENTATIVE OR SITE SUPERVISOR OF ANY EXISTING UNDERGROUND UTILITIES AND/OR EASEMENTS PRIOR TO THE INSTALLATION OF PLANT MATERIAL. CALL 811 AS NECESSARY.
5. ALL TREES, SHRUBS AND GROUNDCOVERS SHALL RECEIVE 3" DEEP LAYER OF SHREDDED FLORMULCH.
6. LANDSCAPE CONTRACTOR IS RESPONSIBLE FOR THEIR OWN QUANTITY TAKE OFF, IN CASE OF ANY DISCREPANCIES, PLAN SHALL TAKE PRECEDENCE OVER PLANT LIST.
7. SOLID SOD SHALL BE ST. AUGUSTINE FLORATAM.
8. THERE SHALL BE A 24" WIDE STRIP OF FLORMULCH BETWEEN SOD AND SHRUBS/GROUNDCOVERS.
9. TERRA-SORB MOISTURE RETENTION GRANULES SHALL BE ADDED TO ALL TREE/PALM PITS AT THE RATE RECOMMENDED BY MANUFACTURER.
10. PLANTING SOIL SHALL CONSIST OF AN EVENLY BLENDED MIX OF 50% MUCK, 25% SAND, 15% SPHAGNUM PEAT MOSS & 10% SHEEP MANURE. TWO LBS. OF FERTILIZER SHALL BE ADDED TO EACH CUBIC YARD OF SOIL & THOROUGHLY MIXED. PLANTING SOIL SHALL HAVE A PH OF BETWEEN 6.0 & 7.0 AFTER MIXING & ADDITION OF FERTILIZER.
11. TOPSOIL MIX SHALL CONSIST OF 80% SAND & 20% MUCK THOROUGHLY MIXED WITH A COMMERCIAL SHREDDER. MIX SHALL BE FREE OF ROCKS, LIMBS, ROOTS & OTHER MATTER.
12. ALL EXISTING SOD OUTSIDE THE LIMIT OF WORK LINE DAMAGED DURING CONSTRUCTION SHALL BE REPLACED WITH SAME SPECIES AT NO COST TO OWNER.
13. ALL PLANTING BEDS MUST BE FREE OF SURFACE ROCK WITH A DIAMETER OF 1/2" OR GREATER PRIOR TO INSTALLATION OF WEED FABRIC AND/OR PLANT MATERIAL.
14. ALL PLANT MATERIAL, EXCLUDING SOD, TO BE WARRANTED AS FOLLOWS: SHRUBS AND GROUNDCOVER FOR 90 DAYS, LARGE SHRUBS (OVER 10 GAL.) AND SMALL PALMS FOR 180 DAYS, & LAND B&B MATERIAL FOR 360 DAYS PROVIDED THAT PLANT MATERIAL IS RECEIVING PROPER MAINTENANCE PRESCRIBED BY LANDSCAPE CONTRACTOR.
Note: Acts of God (hurricanes) and other causes beyond the control of the landscape contractor are not covered, the Landscape contractor are not covered.
15. ALL WARRANTIES TO RUN CONCURRENTLY, BEGINNING UPON LANDSCAPE ARCHITECT'S FINAL ACCEPTANCE OF THE INSTALLATION, UNLESS OWNER OR GC REQUIRES CONSTRUCTION PHASING BEYOND CONTROL OF THE INSTALLER.
16. WATERING IS THE RESPONSIBILITY OF THE INSTALLER DURING THE INSTALLATION PHASE UNTIL FINAL ACCEPTANCE.
17. LANDSCAPE CONTRACTOR IS RESPONSIBLE FOR COORDINATING THEIR WORK WITH THE IRRIGATION CONTRACTOR. TREES SHALL NOT BE PLANTED ON TOP OF IRRIGATION LINES.
18. LANDSCAPE CONTRACTOR IS RESPONSIBLE TO ASSURE IRRIGATION INSTALLATION IS PROPERLY PROGRESSING AND IN THE END ADEQUATE FOR GOOD GROWTH. THE OWNER OR GC MUST BE NOTIFIED IN WRITING OF ANY PROBLEMS WITH IRRIGATION PHASING OR PERFORMANCE.
19. ANY EXISTING IRRIGATION TO BE RE-USED (IF APPLICABLE) IS TO BE BROUGHT TO A GOOD FUNCTIONING STANDARD TO ENSURE PROPER WATERING OF ALL PLANT MATERIAL.
20. AN UNDERGROUND AUTOMATIC IRRIGATION SYSTEM SHALL BE PROVIDED FOR ALL LANDSCAPE AREAS, THIS IS DESIGNED FOR "HEAD TO HEAD" COVERAGE.
21. PUBLIC RIGHT OF WAY TREES PROPOSED FOR REMOVAL SHALL COMPLY WITH PUBLIC WORKS DEPARTMENT FOR APPROVALS, PERMITS & OTHER SPECIFIC REQUIREMENTS

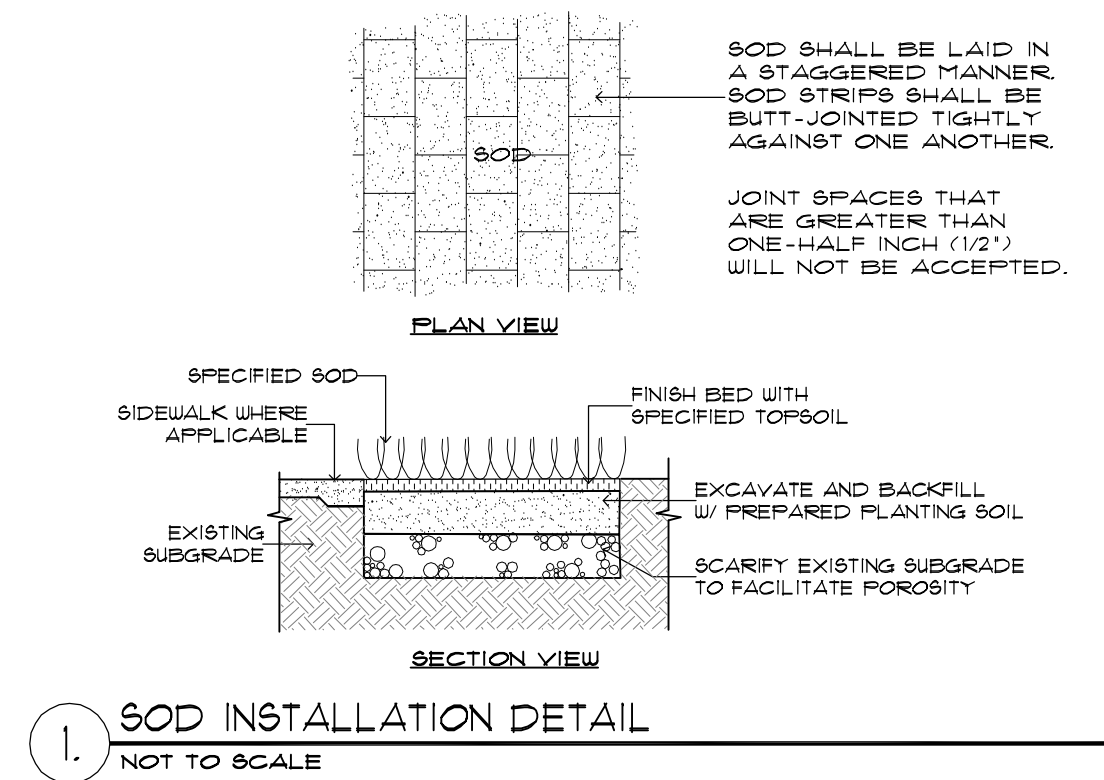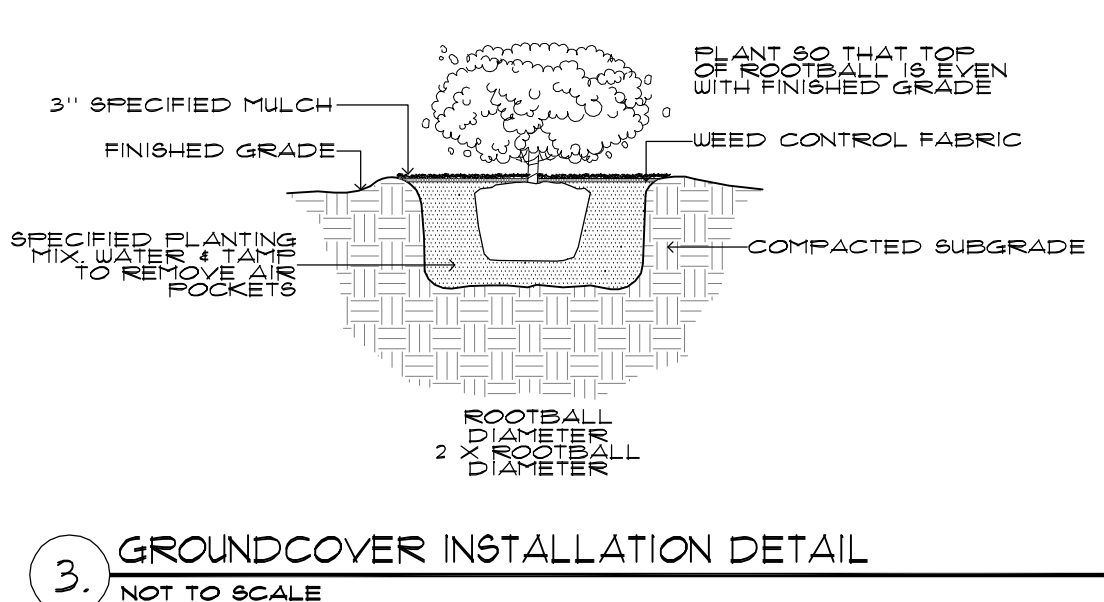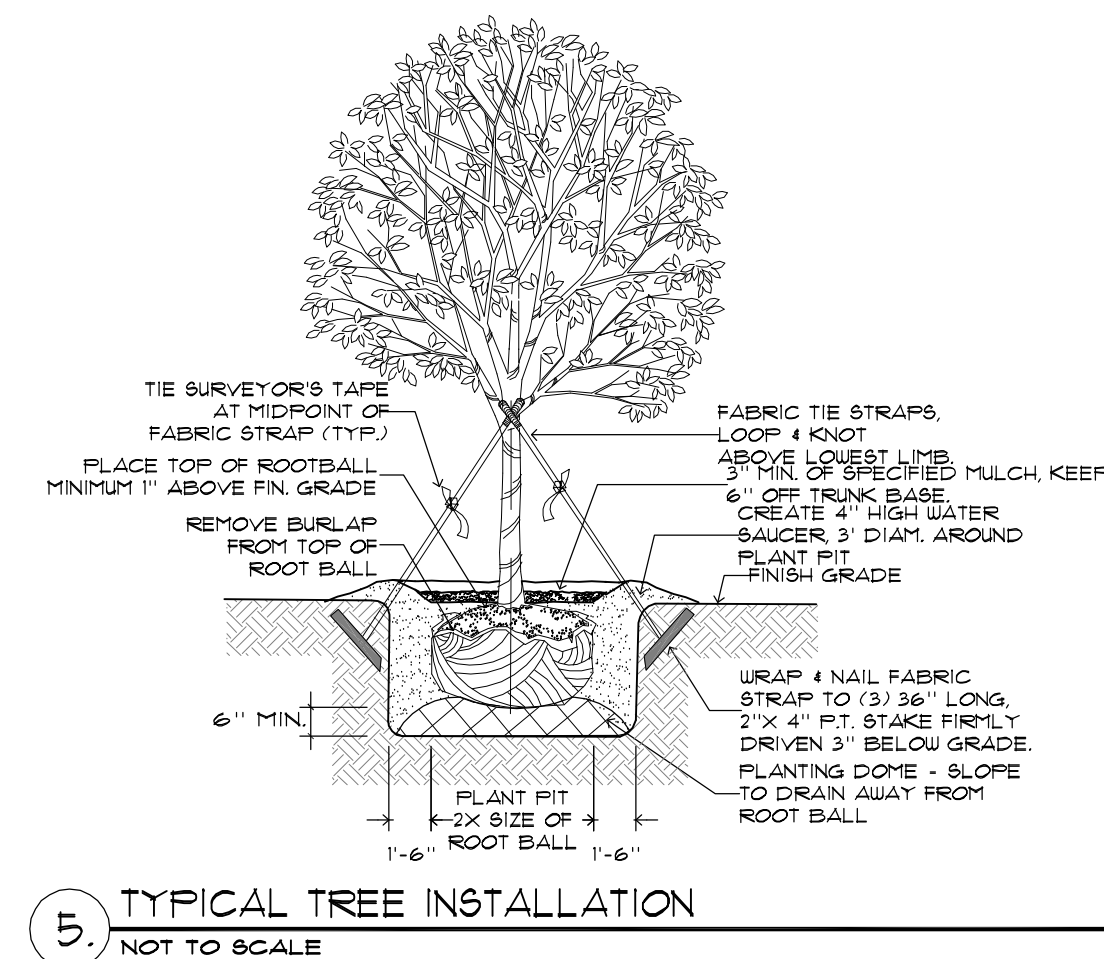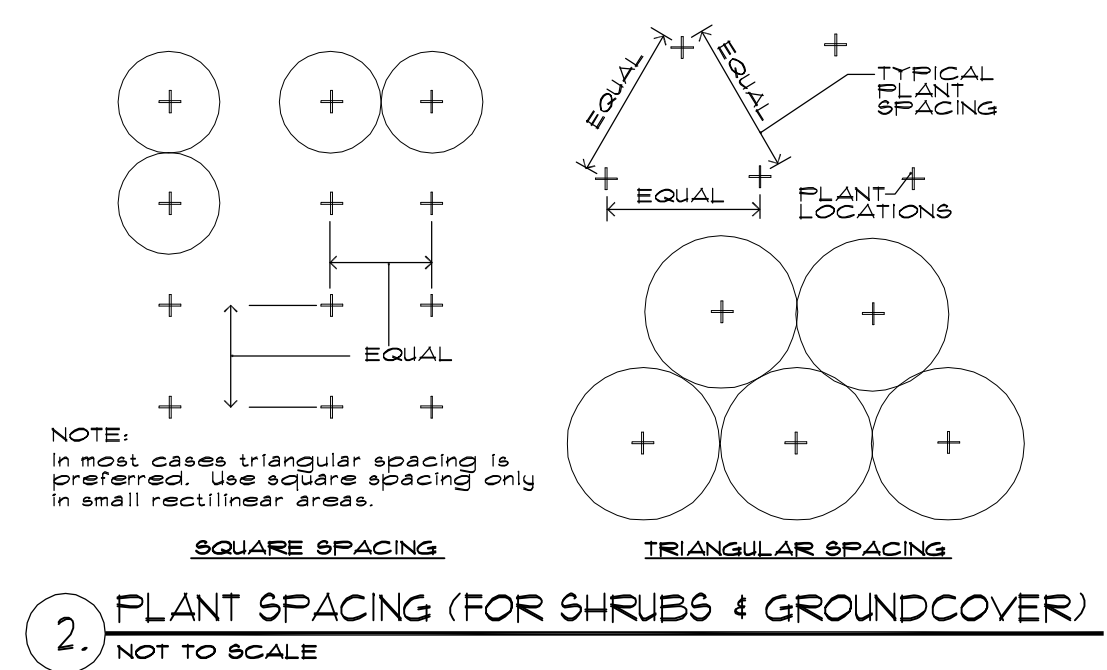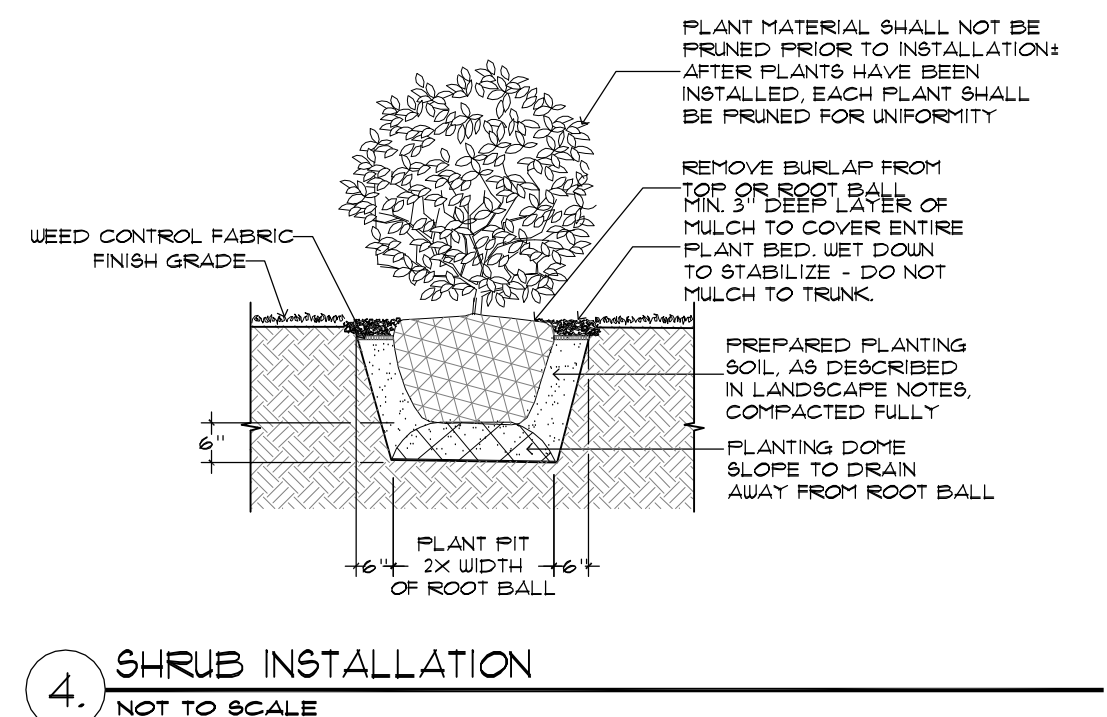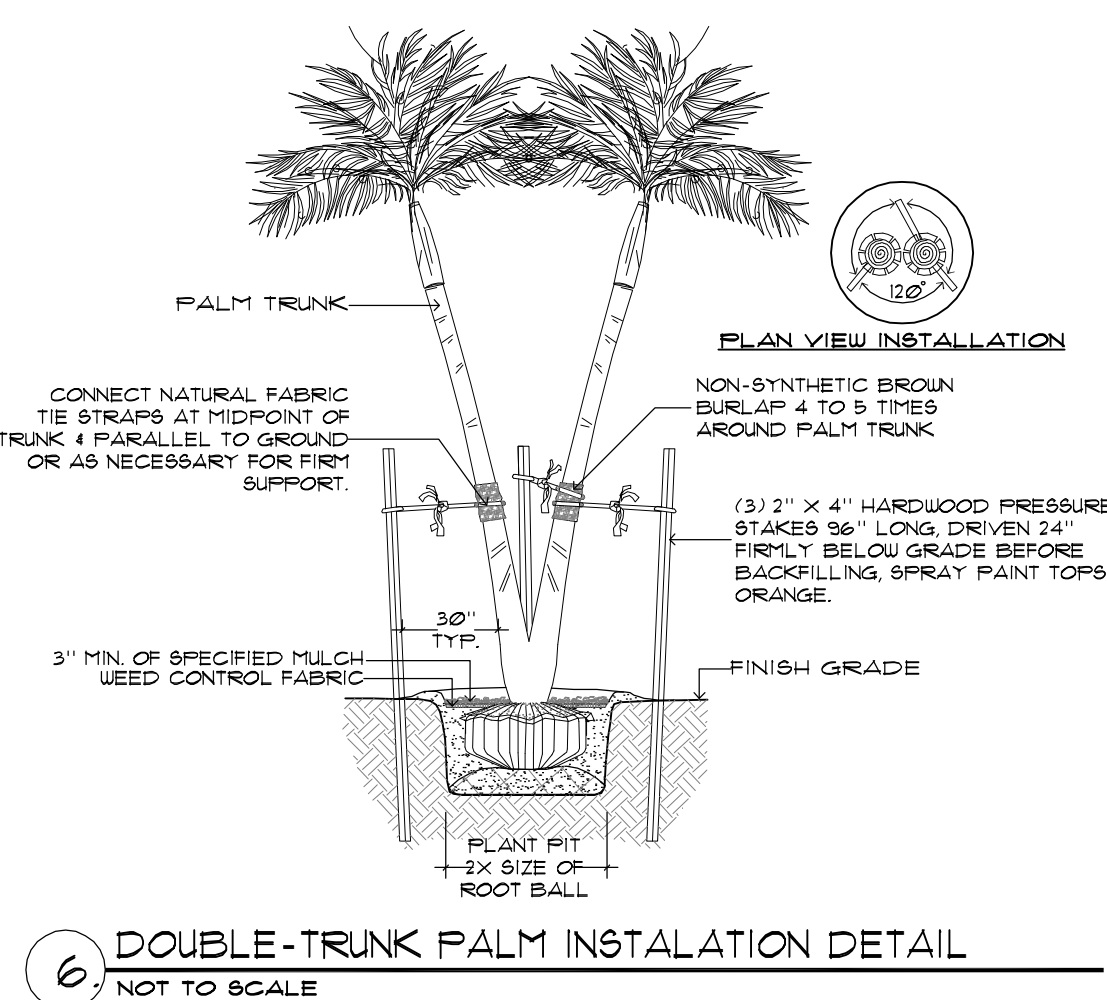

2 LANDSCAPE NOTES AND DETAILS
L-101 Scale: N/A

DESIGNING BEAUTIFUL SPACES
LLA LAURA LLERENA & ASSOCIATES
LANDSCAPE ARCHITECTURE
13170 S.W. 128th Street, Suite 207, Miami, FL 33186
Tel: 305-256-1199 / Fax: 305-256-1155
www.llerena-associates.com

NEW ELEMENTARY SCHOOL (K-5)
VENETIAN PARC WEST
SOUTHWEST 157th AVENUE and 174th STREET
MIAMI, FL. 33187
MDCPS PROJECT No. 01892600


KEY PLAN

CONSULTANT INFO.

RODRIGUEZ ARCHITECTS INCORPORATED
2121 PONCE DE LEON BLVD., STE. 1010
CORAL GABLES, FL.
TEL: (305) 448-3373
FAX: (305) 448-3374
A A C -- 0 0 1 9 3 3

REVISIONS:

DRAWING TITLE:
LANDSCAPE NOTES AND DETAILS
SCALE AS NOTED
ISSUE DATE: 12.16.14
PROJECT NO. 1908
SHEET: **L-101**

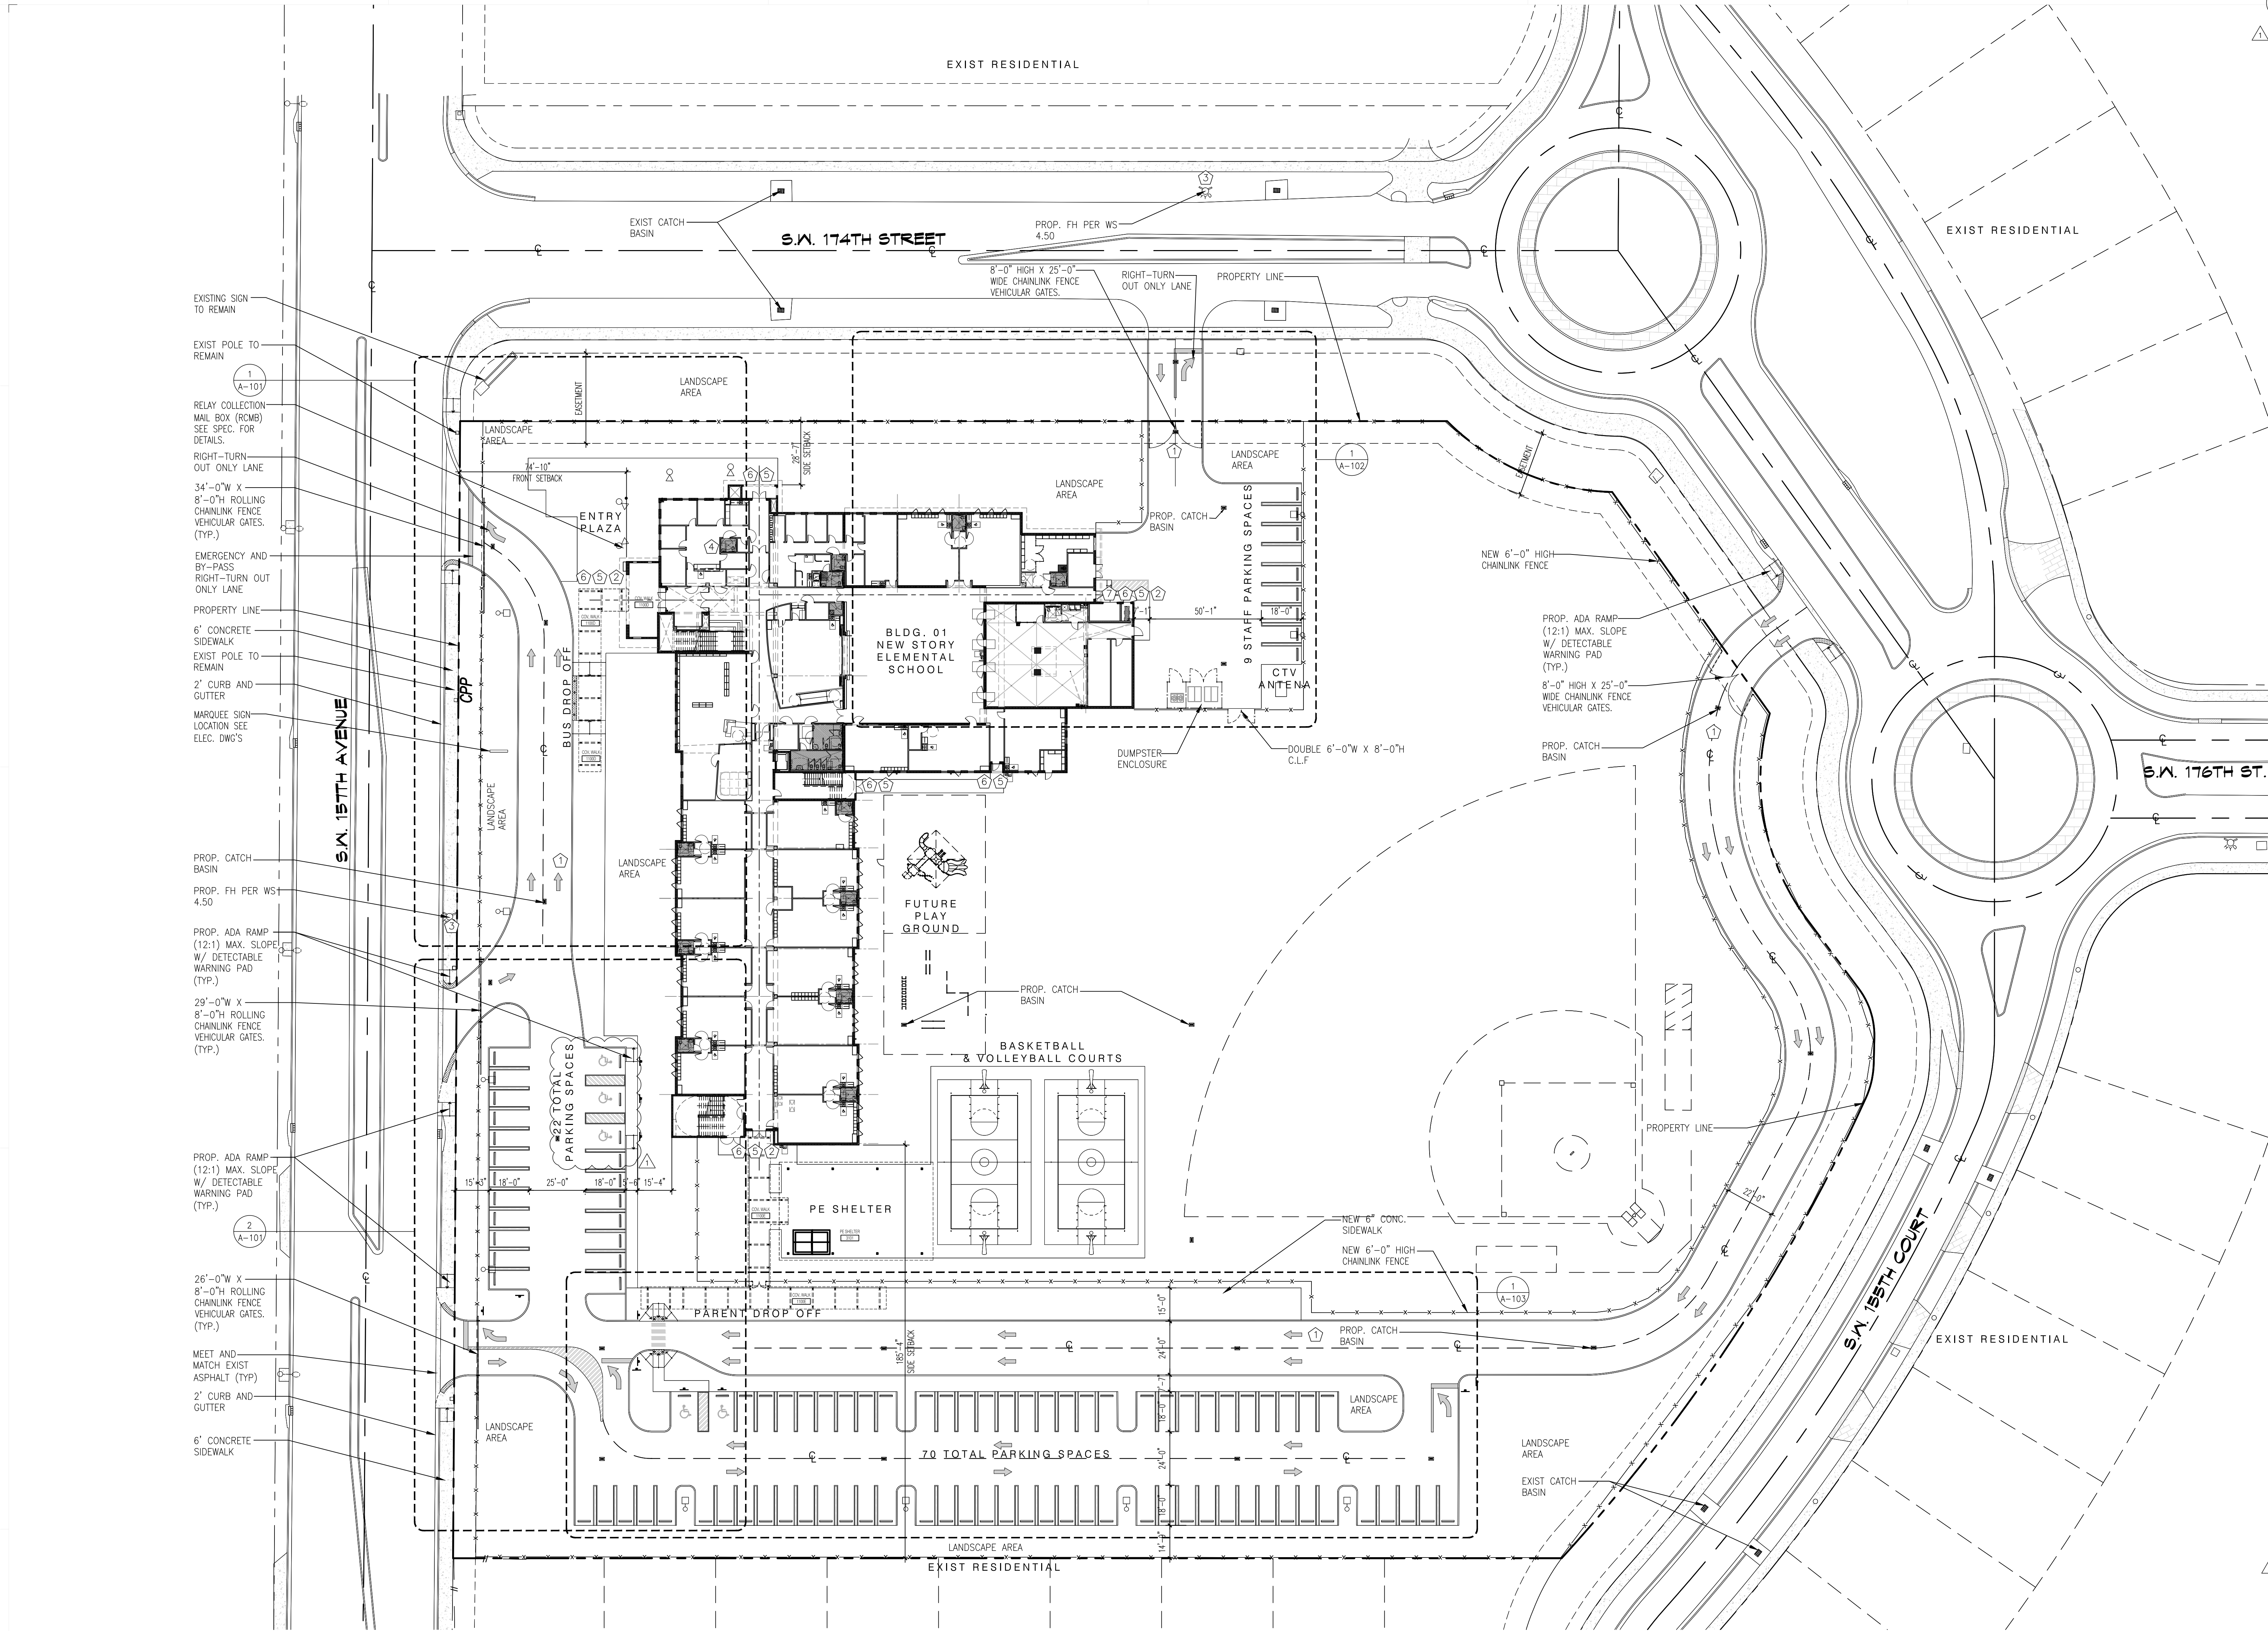

- ### LIFE SAFETY GENERAL NOTES
- ALL NEW CONSTRUCTION SHALL COMPLY WITH THE FLORIDA BUILDING CODE 2017 AND THE 6TH ED. FLORIDA FIRE PROTECTION CODE.
 - ALL NEW SCHOOL CONSTRUCTION IS CONSIDERED EDUCATIONAL OCCUPANCY, TYPE 2B CONSTRUCTION. USE AND OCCUPANCY CLASSIFICATION = E.

PER FBC	TABLES:
MAX. STORIES	3 (504.4)
MAX. HEIGHT	75 FT. (504.3)
MAX. AREA	58,000 SF (506.2)

ASSEMBLY AREAS HAVE BEEN PROVIDED WITHIN THE BUILDING. ASSEMBLY A-3 HAS BEEN CONSIDERED FOR THE MOST STRINGENT CONDITIONS FOR CONSTRUCTION TYPE AND USE, TYPE 2B CONSTRUCTION. USE AND OCCUPANCY CLASSIFICATION = A-3.

PER FBC	TABLES:
MAX. STORIES	3 (504.4)
MAX. HEIGHT	75 FT. (504.3)
MAX. AREA	38,000 SF (506.2)

AREA CALCULATION - NEW ADDITION

	1st FLOOR	2nd FLOOR
36,216 SF		
22,549 SF		
58,765 SF		

58,765 SF TOTAL NEW BUILDING AREA
 - NEW EDUCATIONAL FACILITY BUILDINGS ARE FULLY PROTECTED BY FIRE SPRINKLER SYSTEM. (NON-COMBUSTIBLE CONSTRUCTION COVERED WALKWAYS ARE NOT SPRINKLED.)
 - MAXIMUM TRAVEL DISTANCE = 200 FT.
 - MAXIMUM DEAD END = 20 FT.
 - MAXIMUM COMMON PATH OF TRAVEL = 100 FT.
 - STAIRS = 0.3 IN./OCCUPANT
 - LEVEL COMPONENTS = 0.2 IN./OCCUPANT
 - MINIMUM DOOR WIDTH = 32 IN.
 - OCCUPANCY PER SF AS PER FBC 1004.1.2 AND FFPC 7.3.1.2:

NSF / OCCUPANT LABS	UNCONCENTRATED
50	
15	
15	
15	
20	
100	

NSF / OCCUPANT DINING/MULTIPURPOSE

NSF / OCCUPANT STAGE

NSF / OCCUPANT CLASSROOMS/DRESSING

OSF / OCCUPANT ADMINISTRATION/OFFICES, TEACHER PLANNING, KITCHEN AND SUPPORT SPACES.
 - REFER TO ENLARGED LIFE SAFETY PLANS FOR SPECIFIC SAFETY ITEMS REQUIRED.

- ### FIRE PROTECTION CRITERIA
- THE FOLLOWING FIRE-RESISTANCE RATINGS SHALL BE PROVIDED UNLESS NOTED OTHERWISE. REFERENCE 2017 FBC, 6th ED. TABLE 601.
- TYPE II-B CONSTRUCTION:
- STRUCTURAL FRAME:
- COLUMNS & GIRDERS, BEAMS, TRUSSES, ETC. SHALL BE 0 HOUR PROTECTED
- EXTERIOR/INTERIOR BEARING WALLS:
- EXTERIOR: SHALL BE 0 HOUR PROTECTED
- INTERIOR: SHALL BE 0 HOUR PROTECTED
- FLOOR CONSTRUCTION:
- BETWEEN LEVELS SHALL BE 0 HOUR PROTECTED INCLUDING SUPPORTING BEAMS AND JOISTS
- ROOF CONSTRUCTION:
- SHALL BE 0 HOUR PROTECTED.
- FIRE RESISTANCE RATINGS FOR EXTERIOR WALLS:
- AS PER 2017 FBC, 6th ED. TABLE 602
- | <5 (FT) | 1 HR RATING |
|----------------------------------|-------------|
| >5<10 (FT) <td>1 HR RATING</td> | 1 HR RATING |
| >10<30 (FT) <td>0 HR RATING</td> | 0 HR RATING |
| >30 (FT) <td>0 HR RATING</td> | 0 HR RATING |
- ALLOWABLE AREA OF OPENING (AS PER 2017 FBC, 6th ED. TABLE 705.8)
- | X'3' = NP | 3' < X <= 5' = 15% | 5' < X <= 10' = 25% |
|----------------------|----------------------|---------------------|
| 10' < X <= 15' = 45% | 15' < X <= 20' = 75% | 20' < X <= 25' = N |
| 25' < X <= 30' = N | 30' < X = N | |
| NP = NOT PERMITTED | | |
| N = NO LIMIT | | |
- INTERIOR FINISHES:
- CLASSIFIED IN ACCORDANCE WITH ASTM E 84 OR UL 723.
- WALLS / CEILINGS:
- CLASS A = FLAME SPREAD INDEX 0-25;
- SMOKE-DEVELOPED INDEX 0-450.
- CLASS B = FLAME SPREAD INDEX 26-75;
- SMOKE-DEVELOPED INDEX 0-450.
- CLASS C = FLAME SPREAD INDEX 76-200;
- SMOKE-DEVELOPED INDEX 0-450
- a. EXITS = CLASS 'A' (FFP101 - 14.3.3.2 (1)
- b. SPACES OTHER THAN EXITS = CLASS 'B' (FFP101 - 14.3.3.2 (2)
- FLOORS:
- CLASSIFICATIONS DETERMINED BY NFPA 253 AS FOLLOWS: CLASS I, 0.45 WATTS/CM2 OR GREATER; CLASS II, 0.22 WATTS/CM2 OR GREATER.
- a. GROUP E/ EDUCATIONAL CLASS II.


- ### CODE ANALYSIS
- INTERIOR CIRCULATION:
- THE INTERIOR MEETING ROOM AND EXTENDED LEARNING AREAS PROVIDED FOR THE CLASSROOM AREAS ARE NOT CONSIDERED CORRIDORS. THESE AREAS ARE CONSIDERED AN INTERVENING SPACE AS PART OF THE OVERALL EGRESS EXIT ACCESS. RATED SEPARATION OF THESE INTERVENING STUDY AREAS ARE NOT REQUIRED PER FBC CH. 10 SECTION 1017.1.

- ### KEYED NOTES
- EMERGENCY VEHICLE LANE
 - FIRE DEPARTMENT KNOX BOX NOTE: KNOX BOX LOCATION TO BE COORDINATED WITH FIRE DEPT.
 - FIRE HYDRANT (SEE CIVIL DRAWINGS)
 - MAIN FIRE ALARM CONTROL PANEL (SEE ELECTRICAL AND FIRE PROTECTION DRAWINGS)
 - BUILDING EXIT (SEE ENLARGED LIFE SAFETY DWGS.)
 - ACCESSIBLE ROUTE
 - FIRE SPRINKLER LINE ENTRY (SEE CIVIL AND FIRE PROTECTION DRAWINGS)

FIRE PROTECTION, SUPPRESSION AND DETECTION SYSTEM REQUIREMENTS

	REQUIRED	PROVIDED
FIRE SPRINKLER	YES	YES
FIRE ALARM	YES	YES
KITCHEN FIRE SUPPRESSION	YES	YES
FIRE EXTINGUISHERS	YES	YES
SMOKE ALARMS	YES	YES
HEAT DETECTORS	YES	YES

1 LIFE SAFETY SITE PLAN
Scale: 1:30

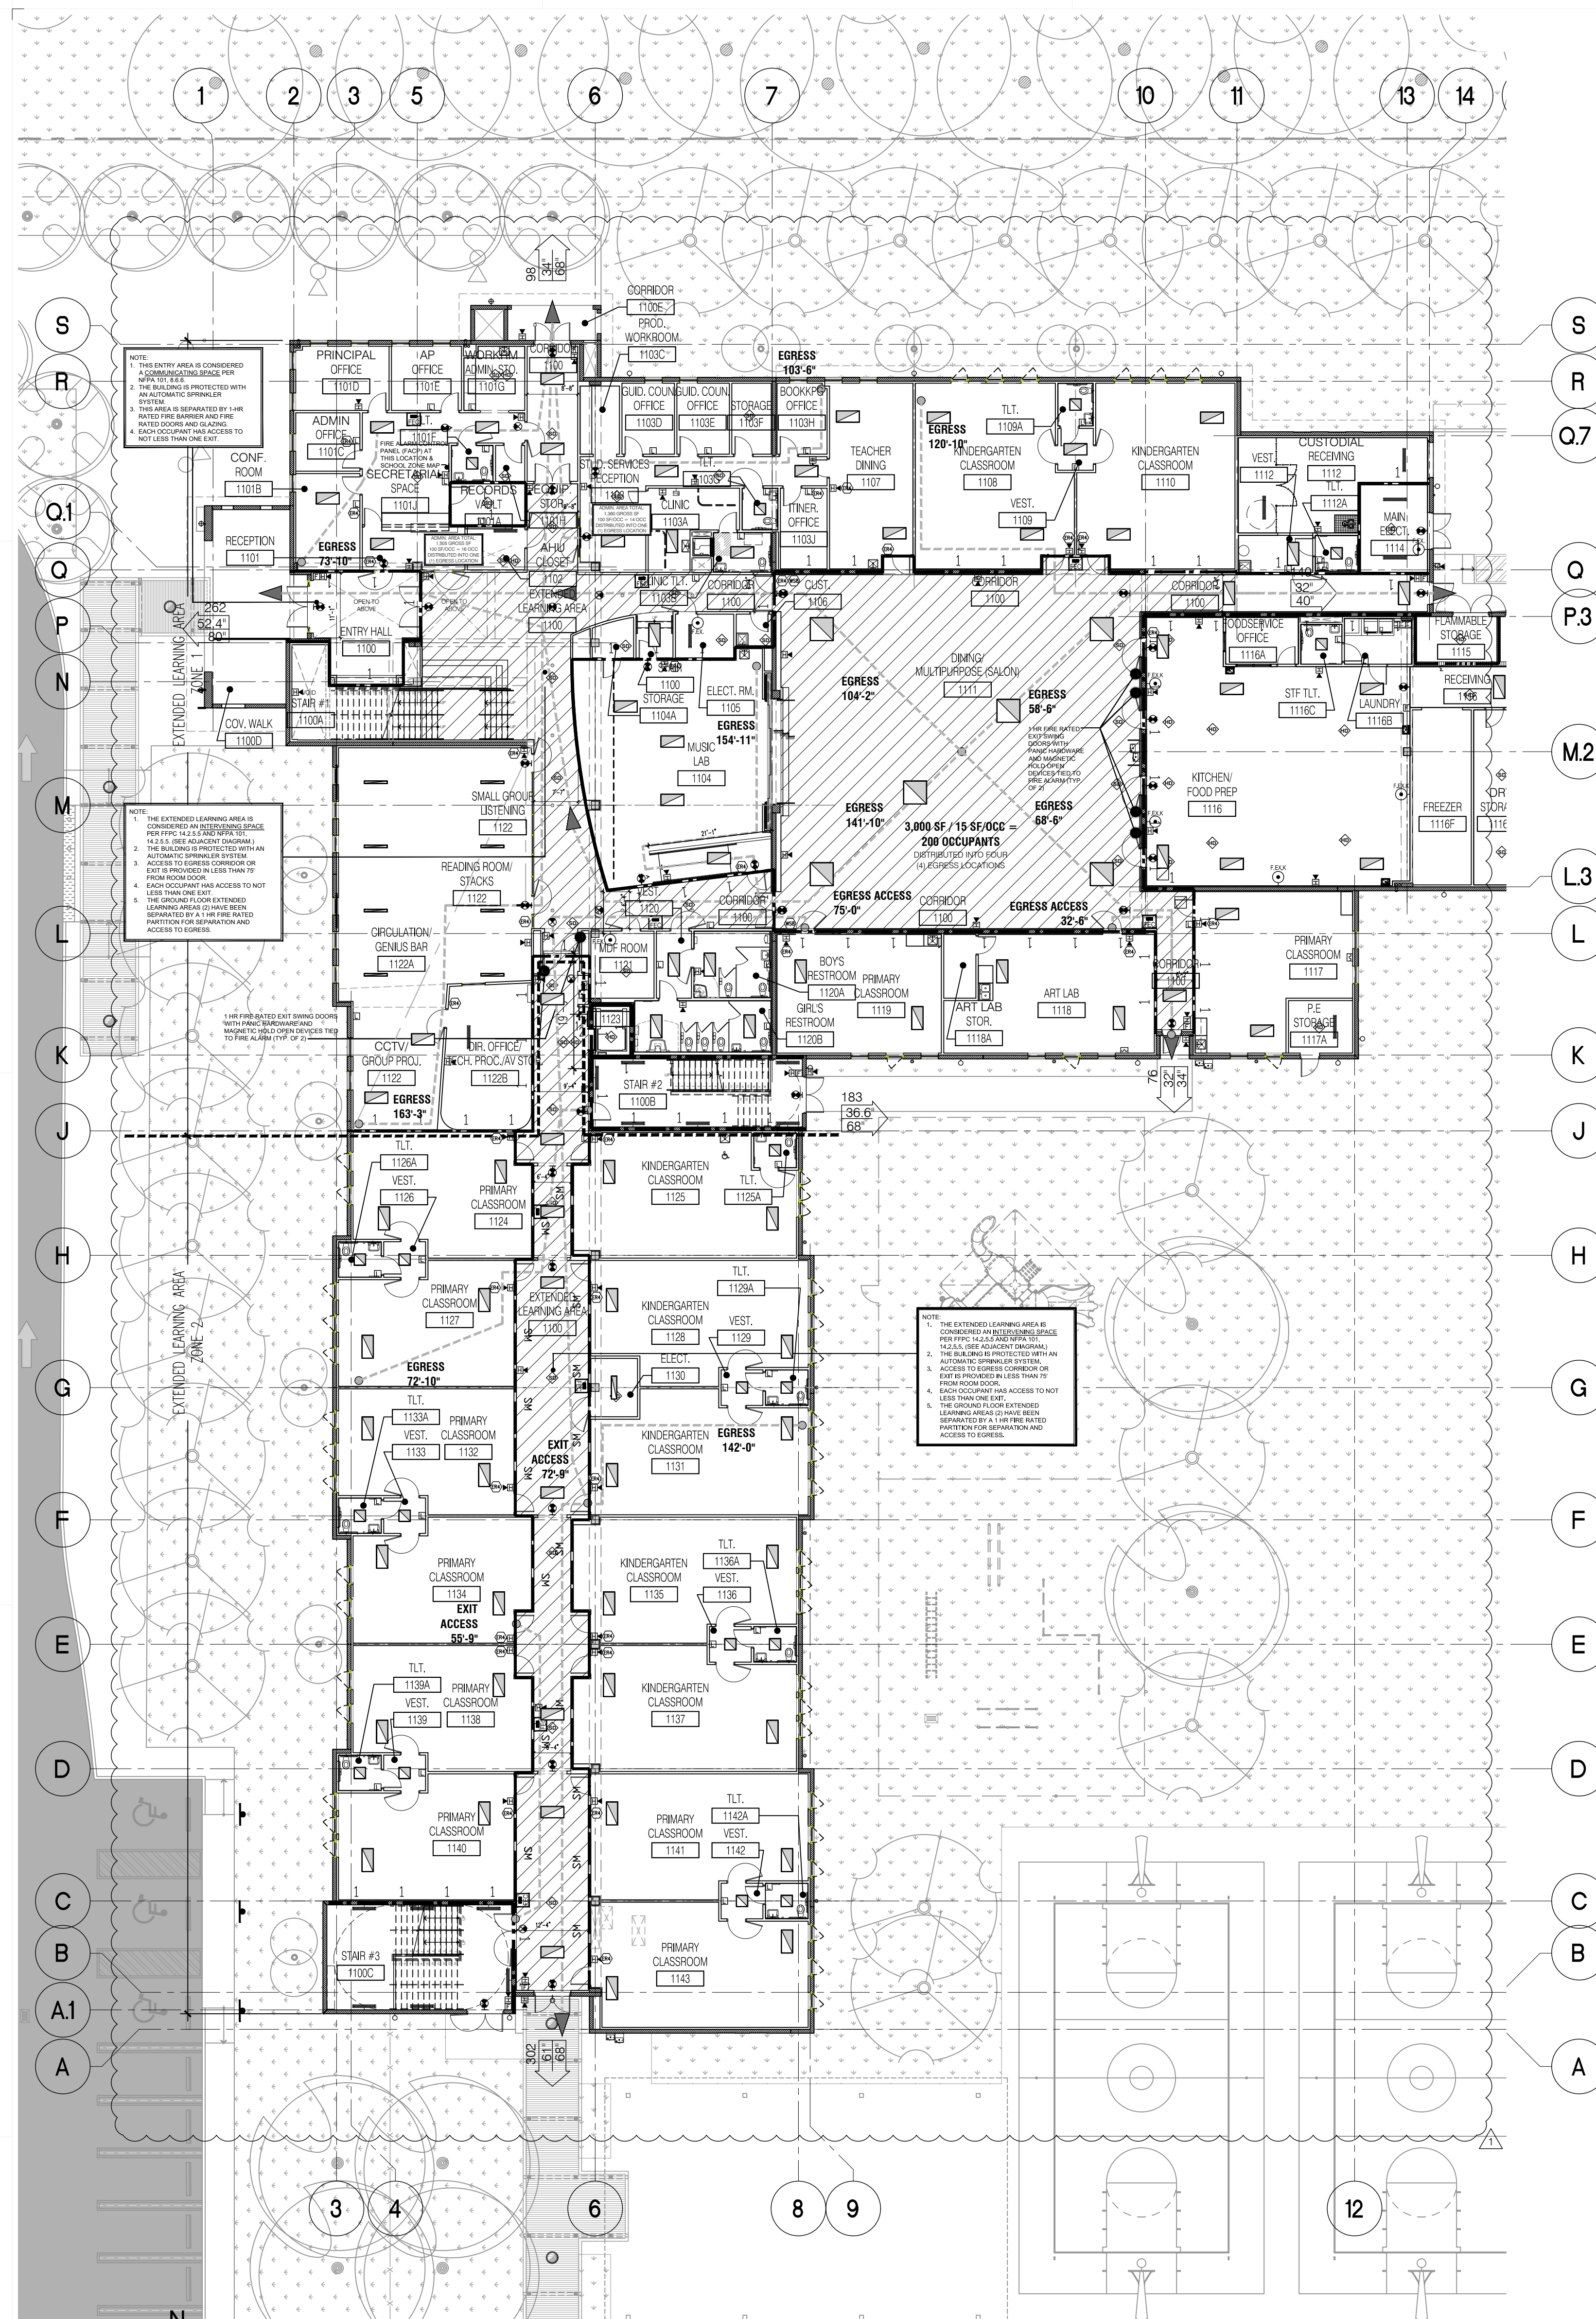


1 OVERALL FIRST FLOOR LIFE SAFETY PLAN
LS-200 Scale: 1/16" = 1'-0"


FIRE EXTINGUISHERS CALCULATIONS

FIRE EXTINGUISHERS TO BE ALL CLASS 2-A
 MAX. AREA PER EXTINGUISHER = 2 * 3000 SF = 6,000 SF.
 1ST FLOOR AREA = 36,216 SF. / 6,000 = MIN. 6 F.E. REQUIRED / 9 F.E. PROVIDED ON CORRIDORS.
 2ND FLOOR AREA = 22,549 SF. / 6,000 = MIN. 4 F.E. REQUIRED / 7 F.E. PROVIDED ON CORRIDORS.
 MAX. 75' DIST. TO EXTINGUISHERS ARE SHOWN ON PLAN.


NFPA / FFPC DIAGRAM 14.2.5.5:

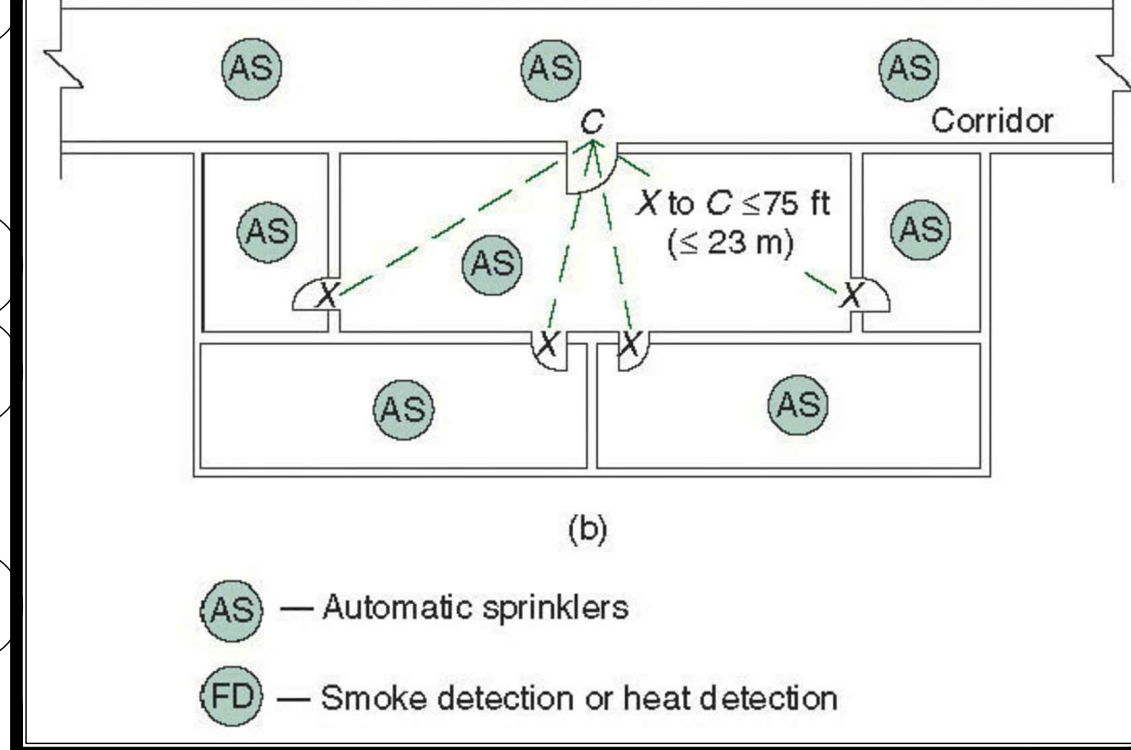

EXTENDED LEARNING AREAS:
 Exit Access
 Intervening Room - FFPC 14.2.5.5
 "Every room that is normally subject to student occupancy shall have an exit access door leading directly to an exit access corridor or exit, unless otherwise permitted by the following:
 (2) One room shall be permitted to intervene between a normally occupied student room and an exit access corridor, provided that all of the following criteria are met:
 (a) the travel from the room served by an intervening room to the corridor exit or exit shall not exceed 75 feet;
 (b) clothing, personal effects, or other materials deemed hazardous by the authority having jurisdiction shall be stored in metal lockers, provided that they do not obstruct the exit access, or the intervening room shall be sprinkled in accordance with Section 9.7;
 (c) one of the following means of protection shall be provided:
 (i) the intervening room shall have fire detection that activates the building alarm;
 (ii) the building shall be protected by an approved, supervised automatic sprinkler system in accordance with Section 9.7."

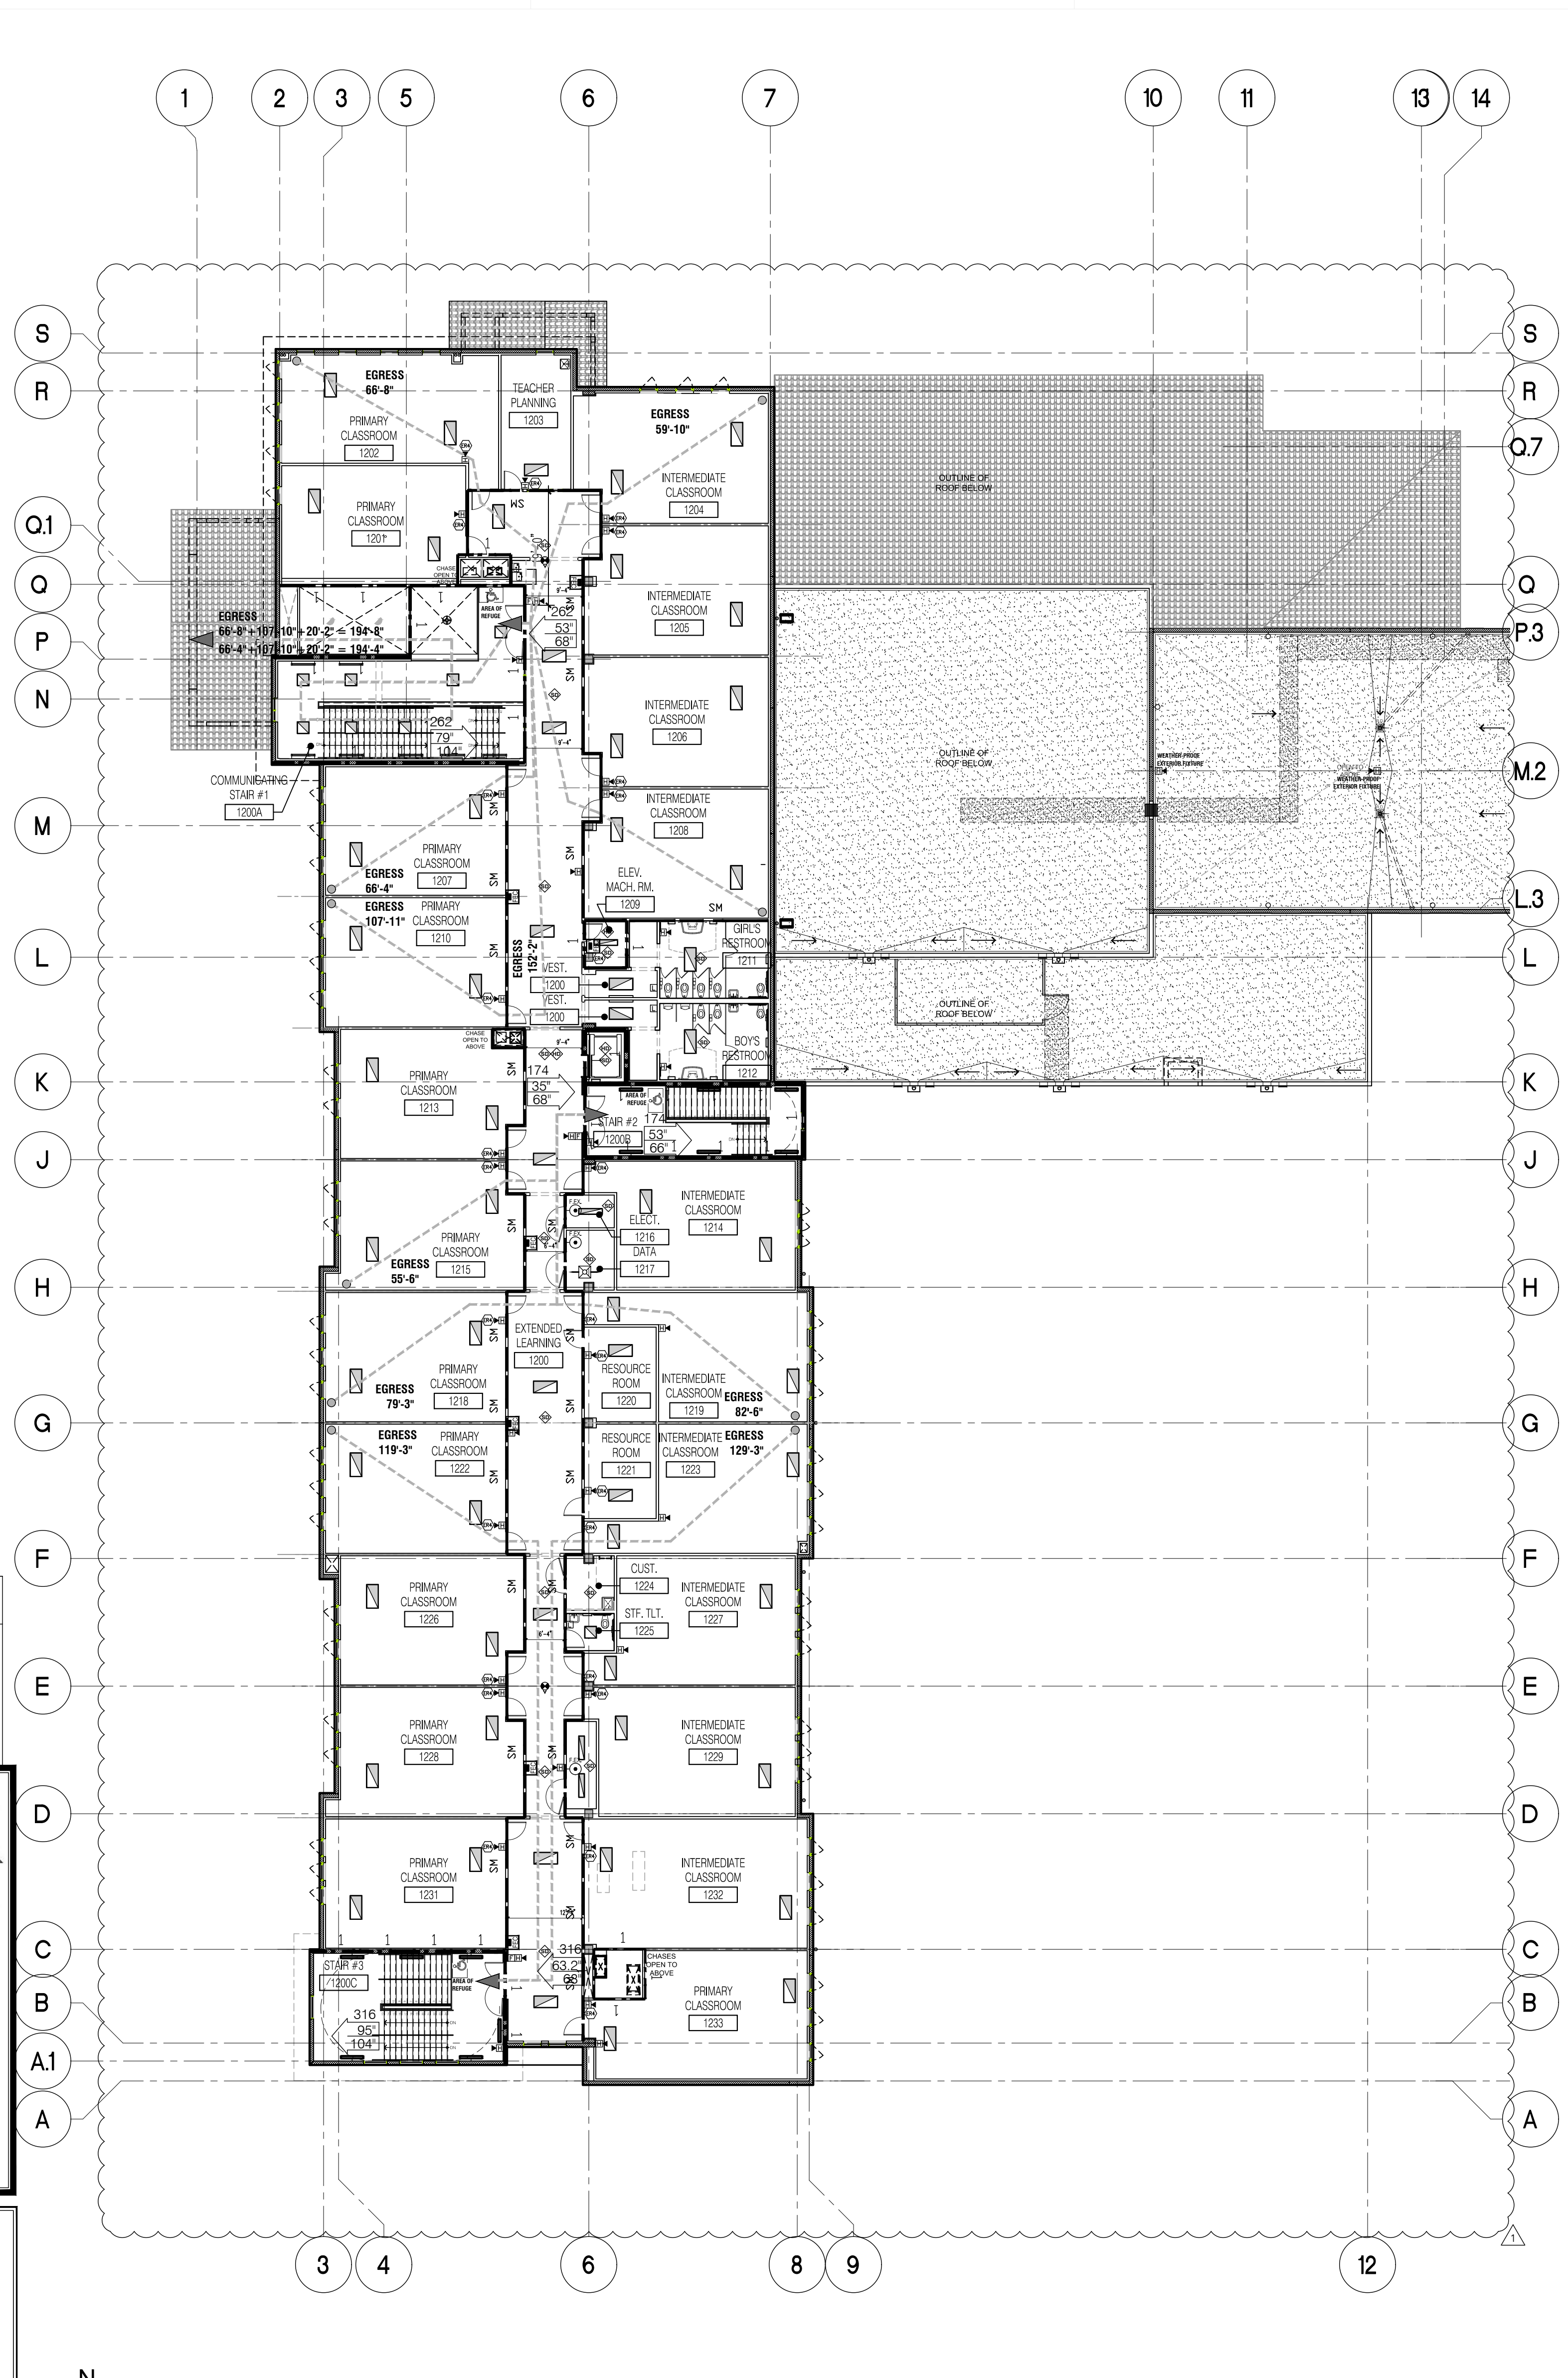

1 OVERALL SECOND FLOOR LIFE SAFETY PLAN
LS-200 Scale: 1/16" = 1'-0"

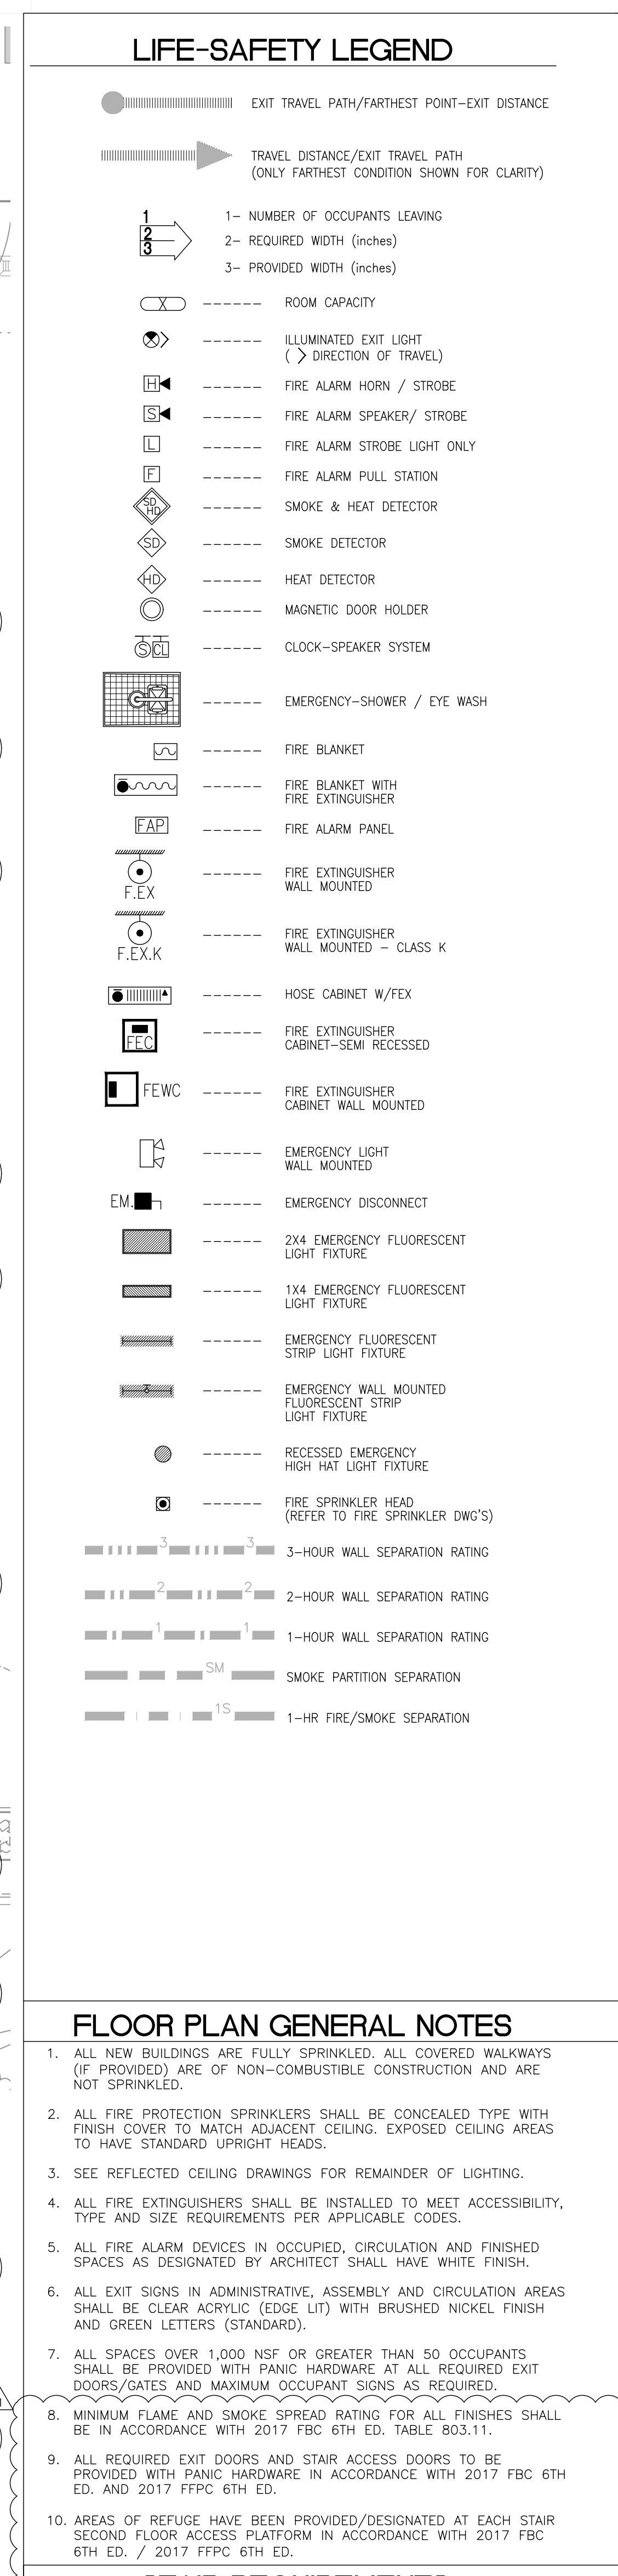

STAIR REQUIREMENTS		
BUILDING No. 01	EXIT #	WIDTH
OCCUPANCY SECOND FLOOR		
OCCUPANCY BUILDING 1: 747 OCC.	STAIR #1	104"
TOTAL OCCUPANTS 747 OCC.	STAIR #2	66"
	STAIR #3	104"
STAIRS = 0.3 IN./OCCUPANT		
0.3/747 OCC = 224.1" REQUIRED		
	TOTAL PROVIDED	274"
	TOTAL REQUIRED	224.1"

TS

DRAWING TITLE:


**ENLARGED 1ST FL
LIFE SAFETY PLAN
AREA A**

SCALE AS NOTED

ISSUE DATE:	PROJECT NO.
12.16.19	1906

SHEET:

LS-211

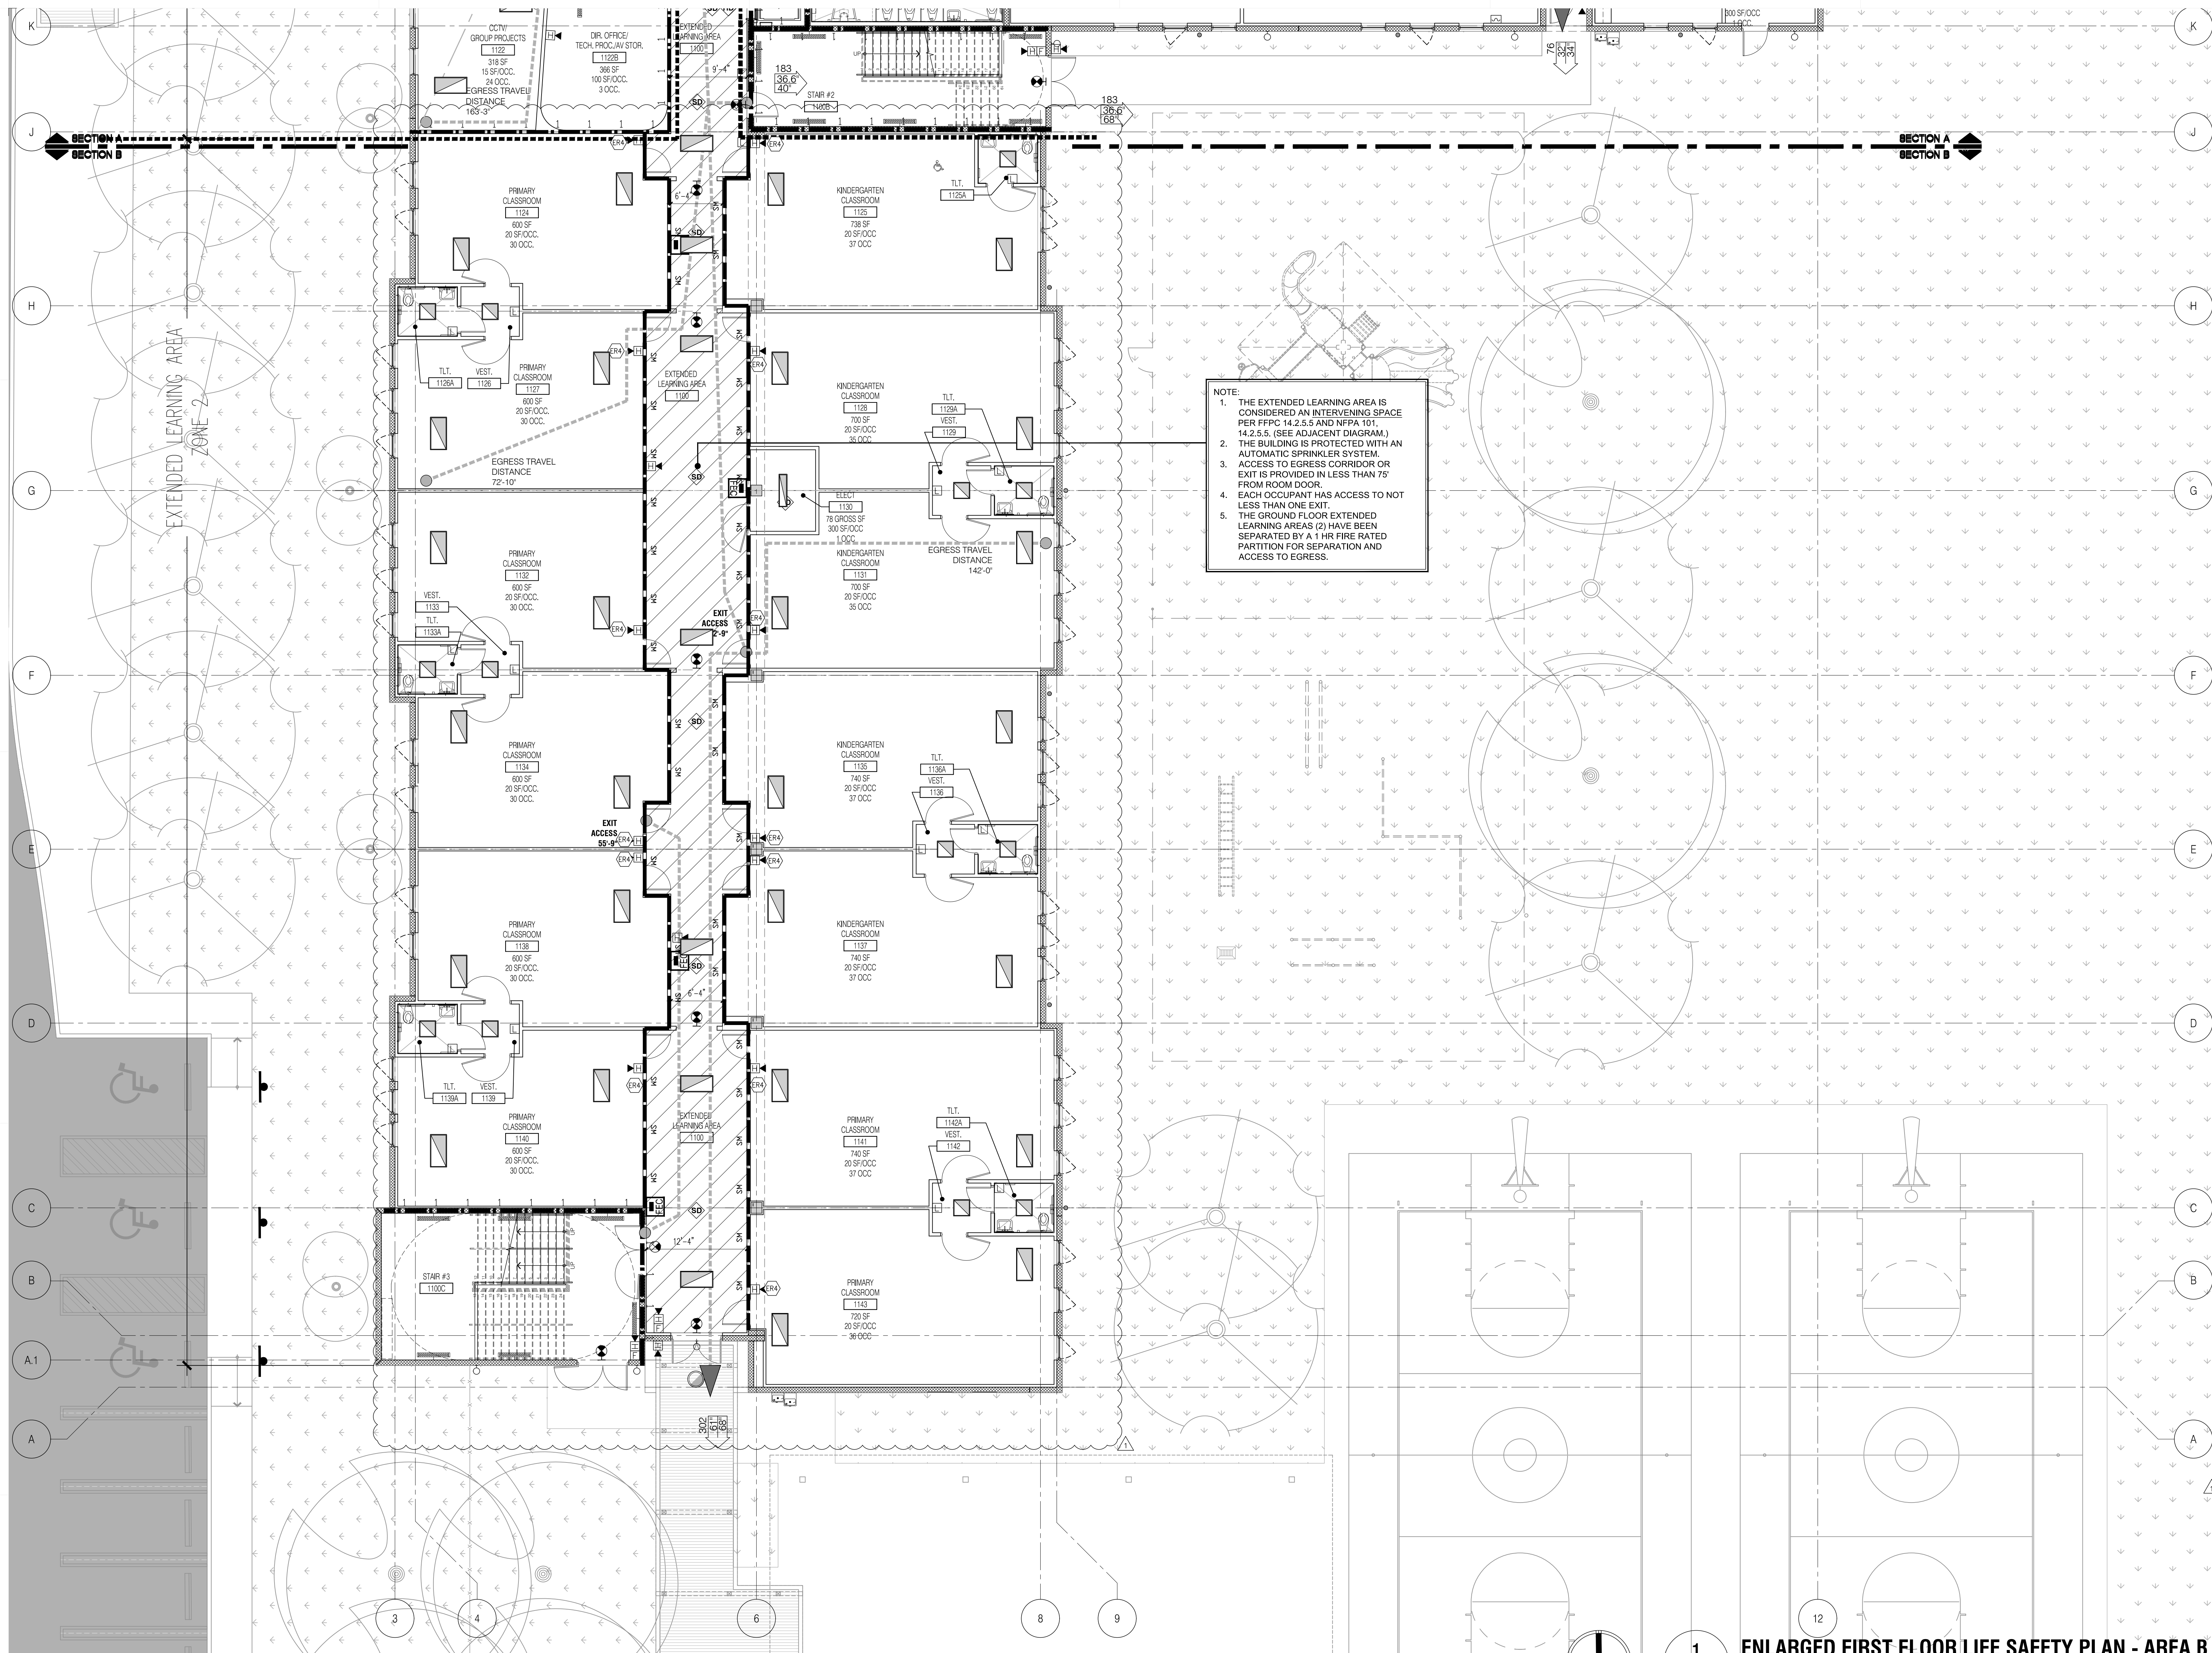

NOTE:
1. THE EXTENDED LEARNING AREA IS CONSIDERED AN INTERVENING SPACE PER FFPC 14.2.5.5 AND NFPA 101, 14.2.5.5. (SEE ADJACENT DIAGRAM).
2. THE BUILDING IS PROTECTED WITH AN AUTOMATIC SPRINKLER SYSTEM.
3. ACCESS TO EGRESS CORRIDOR OR EXIT IS PROVIDED IN LESS THAN 75' FROM ROOM DOOR.
4. EACH OCCUPANT HAS ACCESS TO NOT LESS THAN ONE EXIT.
5. THE GROUND FLOOR EXTENDED LEARNING AREAS (2) HAVE BEEN SEPARATED BY A 1-HR FIRE RATED PARTITION FOR SEPARATION AND ACCESS TO EGRESS.

LIFE-SAFETY LEGEND

- EXIT TRAVEL PATH/FARTHEST POINT-EXIT DISTANCE
- TRAVEL DISTANCE/EXIT TRAVEL PATH (ONLY FARTHEST CONDITION SHOWN FOR CLARITY)
- 1- NUMBER OF OCCUPANTS LEAVING
2- REQUIRED WIDTH (inches)
3- PROVIDED WIDTH (inches)
- ROOM CAPACITY
- ILLUMINATED EXIT LIGHT (> DIRECTION OF TRAVEL)
- FIRE ALARM HORN / STROBE
- FIRE ALARM SPEAKER/ STROBE
- FIRE ALARM STROBE LIGHT ONLY
- FIRE ALARM PULL STATION
- SMOKE & HEAT DETECTOR
- SMOKE DETECTOR
- HEAT DETECTOR
- MAGNETIC DOOR HOLDER
- CLOCK-SPEAKER SYSTEM
- EMERGENCY-SHOWER / EYE WASH
- FIRE BLANKET
- FIRE BLANKET WITH FIRE EXTINGUISHER
- FIRE ALARM PANEL
- FIRE EXTINGUISHER WALL MOUNTED
- FIRE EXTINGUISHER WALL MOUNTED - CLASS K
- HOSE CABINET W/FEX
- FIRE EXTINGUISHER CABINET-SEMI RECESSED
- FIRE EXTINGUISHER CABINET WALL MOUNTED
- EMERGENCY LIGHT WALL MOUNTED
- EMERGENCY DISCONNECT
- 2X4 EMERGENCY FLUORESCENT LIGHT FIXTURE
- 1X4 EMERGENCY FLUORESCENT LIGHT FIXTURE
- EMERGENCY FLUORESCENT STRIP LIGHT FIXTURE
- EMERGENCY WALL MOUNTED FLUORESCENT STRIP LIGHT FIXTURE
- RECESSED EMERGENCY HIGH HAT LIGHT FIXTURE
- FIRE SPRINKLER HEAD (REFER TO FIRE SPRINKLER DWG'S)
- 3-HOUR WALL SEPARATION RATING
- 2-HOUR WALL SEPARATION RATING
- 1-HOUR WALL SEPARATION RATING
- SMOKE PARTITION SEPARATION
- 1-HR FIRE/SMOKE SEPARATION


FLOOR PLAN GENERAL NOTES

- ALL NEW BUILDINGS ARE FULLY SPRINKLED. ALL COVERED WALKWAYS (IF PROVIDED) ARE OF NON-COMBUSTIBLE CONSTRUCTION AND ARE NOT SPRINKLED.
- ALL FIRE PROTECTION SPRINKLERS SHALL BE CONCEALED TYPE WITH FINISH COVER TO MATCH ADJACENT CEILING. EXPOSED CEILING AREAS TO HAVE STANDARD UPRIGHT HEADS.
- SEE REFLECTED CEILING DRAWINGS FOR REMAINDER OF LIGHTING.
- ALL FIRE EXTINGUISHERS SHALL BE INSTALLED TO MEET ACCESSIBILITY, TYPE AND SIZE REQUIREMENTS PER APPLICABLE CODES.
- ALL FIRE ALARM DEVICES IN OCCUPIED, CIRCULATION AND FINISHED SPACES AS DESIGNATED BY ARCHITECT SHALL HAVE WHITE FINISH.
- ALL EXIT SIGNS IN ADMINISTRATIVE, ASSEMBLY AND CIRCULATION AREAS SHALL BE CLEAR ACRYLIC (EDGE LIT) WITH BRUSHED NICKEL FINISH AND GREEN LETTERS (STANDARD).
- ALL SPACES OVER 1,000 NSF OR GREATER THAN 50 OCCUPANTS SHALL BE PROVIDED WITH PANIC HARDWARE AT ALL REQUIRED EXIT DOORS/GATES AND MAXIMUM OCCUPANT SIGNS AS REQUIRED.
- MINIMUM FLAME AND SMOKE SPREAD RATING FOR ALL FINISHES SHALL BE IN ACCORDANCE WITH 2017 FBC 6TH ED. TABLE 803.11.
- ALL REQUIRED EXIT DOORS AND STAIR ACCESS DOORS TO BE PROVIDED WITH PANIC HARDWARE IN ACCORDANCE WITH 2017 FBC 6TH ED. AND 2017 FFPC 6TH ED.
- AREAS OF REFUGE HAVE BEEN PROVIDED/DESIGNATED AT EACH STAIR SECOND FLOOR ACCESS PLATFORM IN ACCORDANCE WITH 2017 FBC 6TH ED. / 2017 FFPC 6TH ED.

STAIR REQUIREMENTS

BUILDING No. 01	EXIT #	WIDTH
OCCUPANCY SECOND FLOOR:	STAIR #1	104"
OCCUPANCY BUILDING 1: 747 OCC.	STAIR #2	66"
TOTAL OCCUPANTS: 747 OCC.	STAIR #3	104"
STAIRS = 0.3 IN./OCCUPANT		
0.3/747 OCC = 224.1" REQUIRED		
	TOTAL PROVIDED	274"
	TOTAL REQUIRED	224.1"

REVISIONS:	22.14.2020	BUILDING DEPARTMENT COMMENTS:
ENLARGED 1ST FL LIFE SAFETY PLAN AREA B		
SCALE AS NOTED		
ISSUE DATE:	12/16/19	PROJECT NO:
SHEET:		
LS-212		

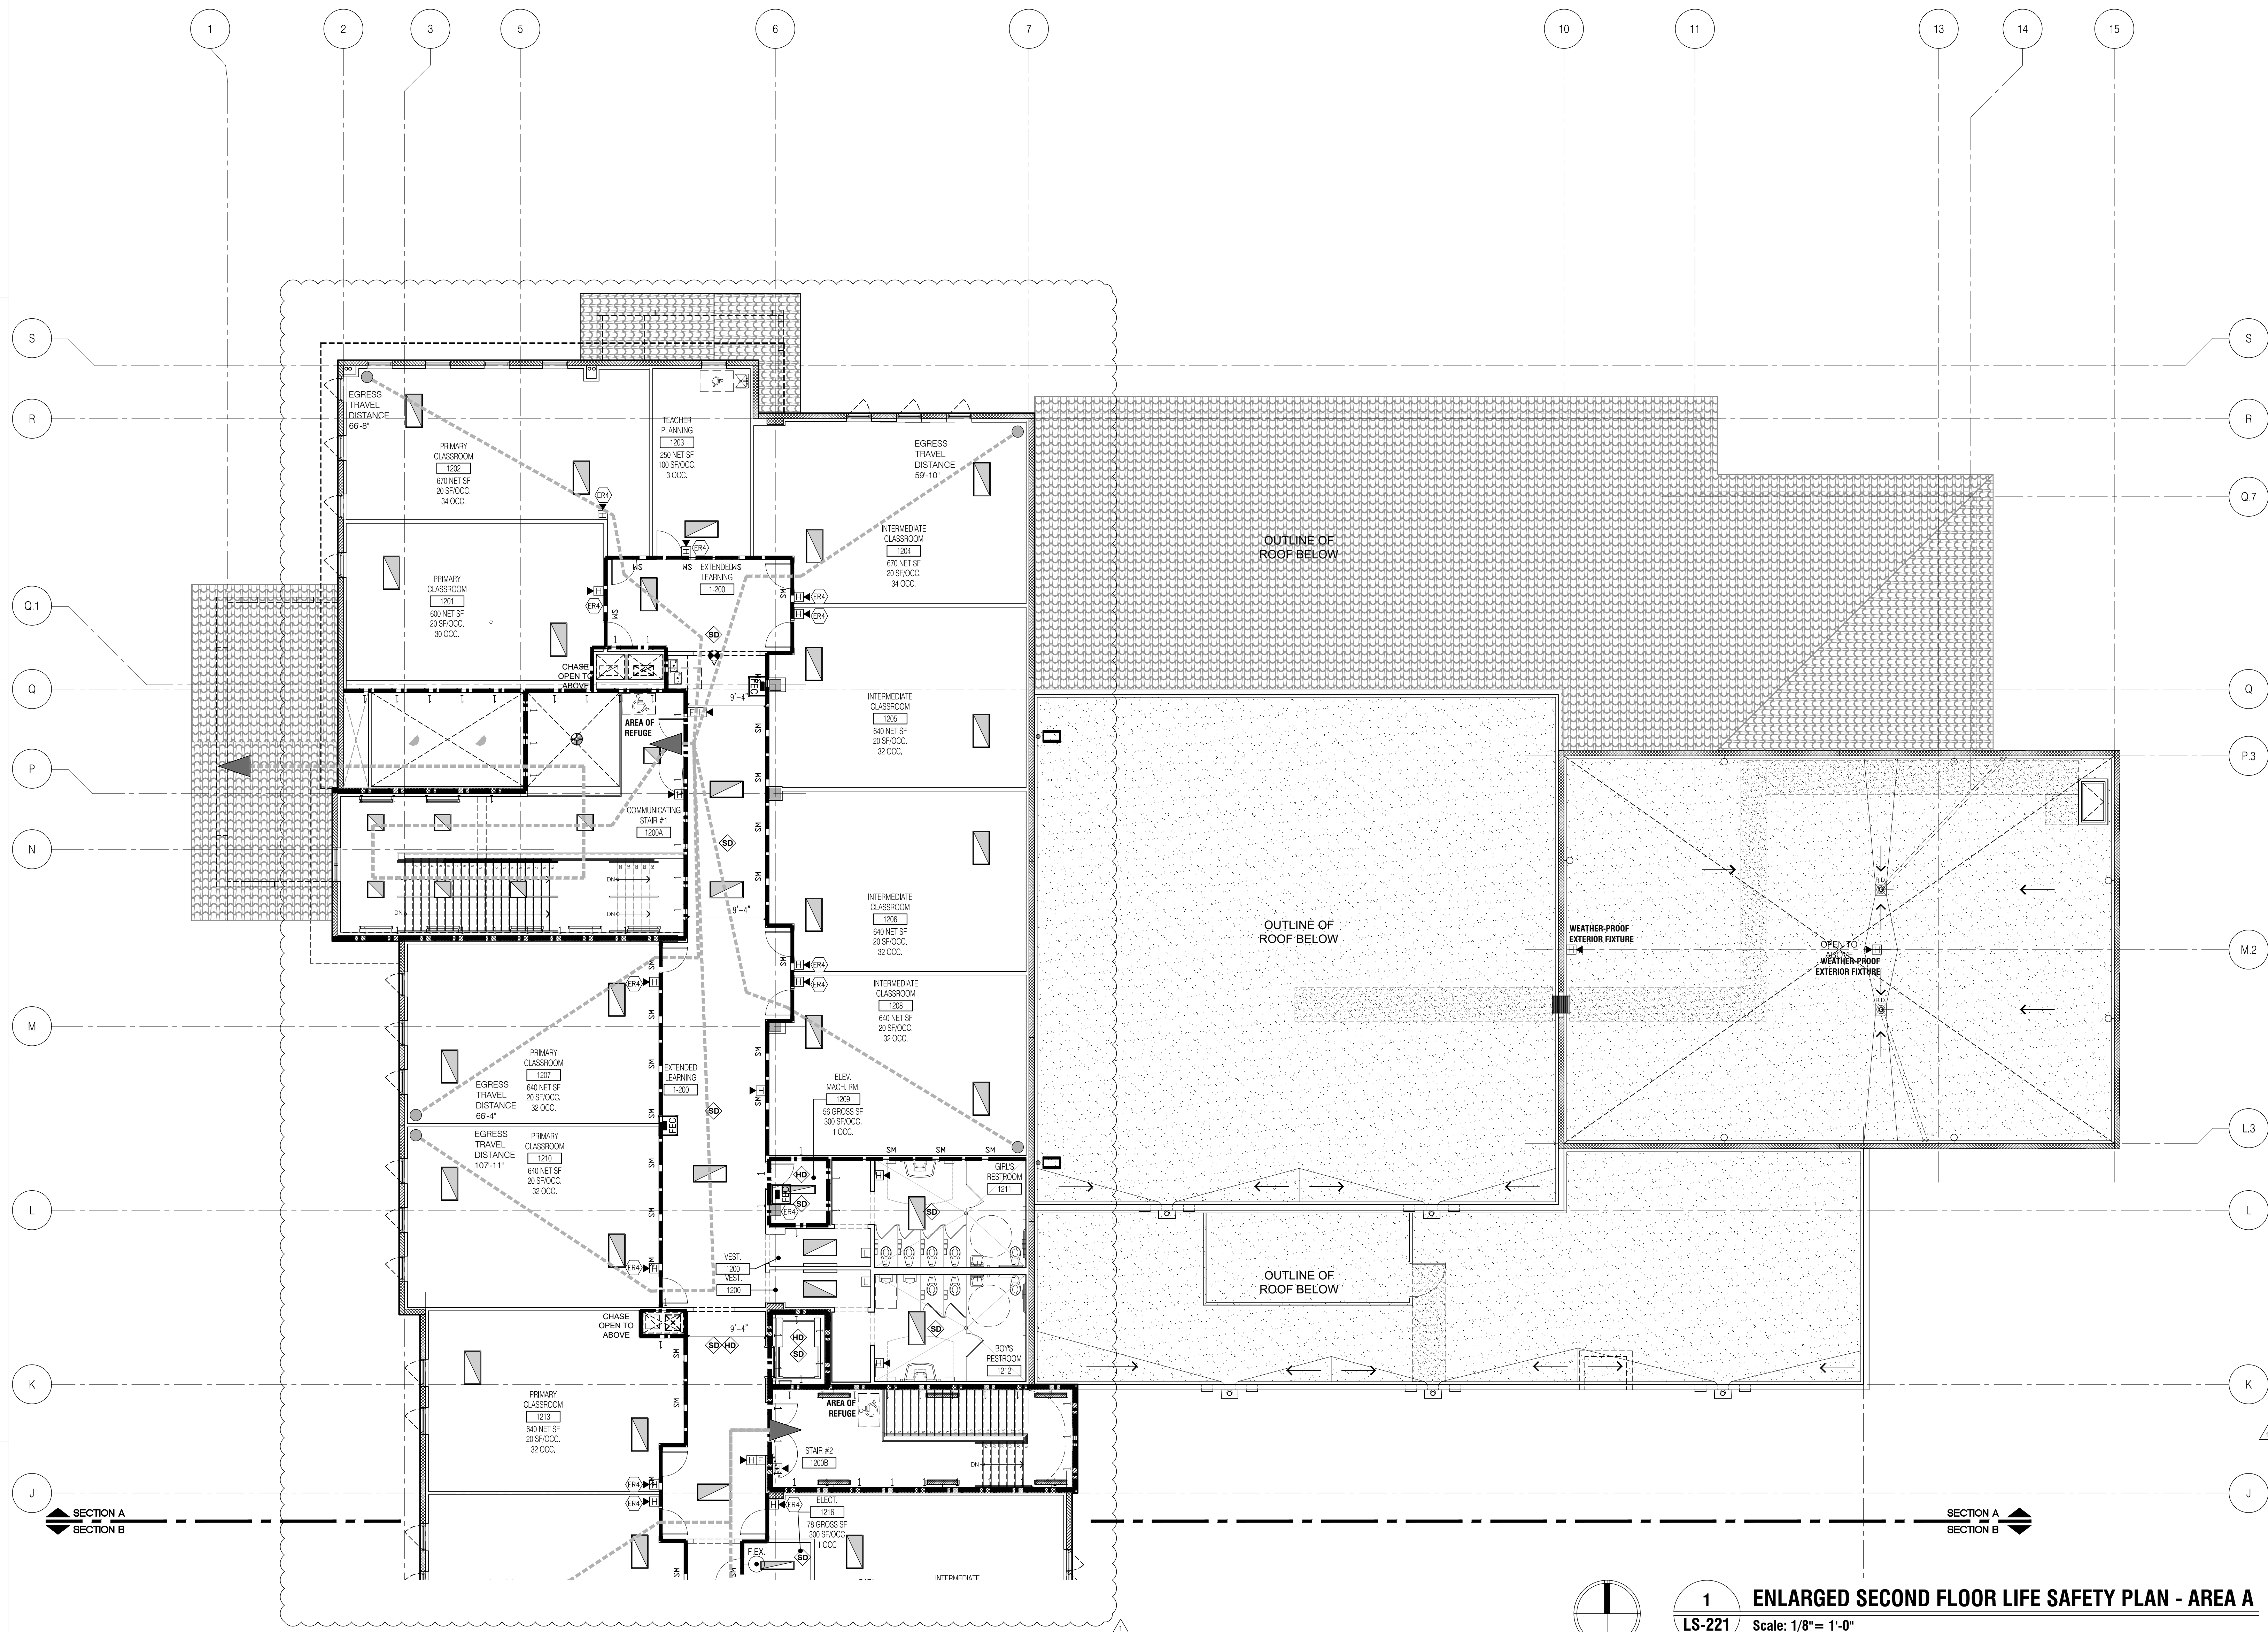

LIFE-SAFETY LEGEND

- EXIT TRAVEL PATH/FARTHEST POINT-EXIT DISTANCE
- TRAVEL DISTANCE/EXIT TRAVEL PATH (ONLY FARTHEST CONDITION SHOWN FOR CLARITY)
- 1- NUMBER OF OCCUPANTS LEAVING
- 2- REQUIRED WIDTH (inches)
- 3- PROVIDED WIDTH (inches)
- ROOM CAPACITY
- ILLUMINATED EXIT LIGHT (> DIRECTION OF TRAVEL)
- FIRE ALARM HORN / STROBE
- FIRE ALARM SPEAKER/ STROBE
- FIRE ALARM STROBE LIGHT ONLY
- FIRE ALARM PULL STATION
- SMOKE & HEAT DETECTOR
- SMOKE DETECTOR
- HEAT DETECTOR
- MAGNETIC DOOR HOLDER
- CLOCK-SPEAKER SYSTEM
- EMERGENCY-SHOWER / EYE WASH
- FIRE BLANKET
- FIRE BLANKET WITH FIRE EXTINGUISHER
- FIRE ALARM PANEL
- FIRE EXTINGUISHER WALL MOUNTED
- FIRE EXTINGUISHER WALL MOUNTED - CLASS K
- HOSE CABINET W/FEX
- FIRE EXTINGUISHER CABINET-SEMI RECESSED
- FIRE EXTINGUISHER CABINET WALL MOUNTED
- EMERGENCY LIGHT WALL MOUNTED
- EMERGENCY DISCONNECT
- 2X4 EMERGENCY FLUORESCENT LIGHT FIXTURE
- 1X4 EMERGENCY FLUORESCENT LIGHT FIXTURE
- EMERGENCY FLUORESCENT STRIP LIGHT FIXTURE
- EMERGENCY WALL MOUNTED FLUORESCENT STRIP LIGHT FIXTURE
- RECESSED EMERGENCY HIGH BAY LIGHT FIXTURE
- FIRE SPRINKLER HEAD (REFER TO FIRE SPRINKLER DWG'S)
- 3-HOUR WALL SEPARATION RATING
- 2-HOUR WALL SEPARATION RATING
- 1-HOUR WALL SEPARATION RATING
- SMOKE PARTITION SEPARATION
- 1-HR FIRE/SMOKE SEPARATION

FLOOR PLAN GENERAL NOTES

- ALL NEW BUILDINGS ARE FULLY SPRINKLED. ALL COVERED WALKWAYS (IF PROVIDED) ARE OF NON-COMBUSTIBLE CONSTRUCTION AND ARE NOT SPRINKLED.
- ALL FIRE PROTECTION SPRINKLERS SHALL BE CONCEALED TYPE WITH FINISH COVER TO MATCH ADJACENT CEILING; EXPOSED CEILING AREAS TO HAVE STANDARD UPRIGHT HEADS.
- SEE REFLECTED CEILING DRAWINGS FOR REMAINDER OF LIGHTING.
- ALL FIRE EXTINGUISHERS SHALL BE INSTALLED TO MEET ACCESSIBILITY, TYPE AND SIZE REQUIREMENTS PER APPLICABLE CODES.
- ALL FIRE ALARM DEVICES IN OCCUPIED, CIRCULATION AND FINISHED SPACES AS DESIGNATED BY ARCHITECT SHALL HAVE WHITE FINISH.
- ALL EXIT SIGNS IN ADMINISTRATIVE, ASSEMBLY AND CIRCULATION AREAS SHALL BE CLEAR ACRYLIC (EDGE LIT) WITH BRUSHED NICKEL FINISH AND GREEN LETTERS (STANDARD).
- ALL SPACES OVER 1,000 NSF OR GREATER THAN 50 OCCUPANTS SHALL BE PROVIDED WITH PANIC HARDWARE AT ALL REQUIRED EXIT DOORS/GATES AND MAXIMUM OCCUPANT SIGNS AS REQUIRED.
- MINIMUM FLAME AND SMOKE SPREAD RATING FOR ALL FINISHES SHALL BE IN ACCORDANCE WITH 2017 FBC 6TH ED. TABLE 803.11.
- ALL REQUIRED EXIT DOORS AND STAIR ACCESS DOORS TO BE PROVIDED WITH PANIC HARDWARE IN ACCORDANCE WITH 2017 FBC 6TH ED. AND 2017 FFPC 6TH ED.
- AREAS OF REFUGE HAVE BEEN PROVIDED/DESIGNATED AT EACH STAIR SECOND FLOOR ACCESS PLATFORM IN ACCORDANCE WITH 2017 FBC 6TH ED. / 2017 FFPC 6TH ED.


STAIR REQUIREMENTS

BUILDING No. 01	EXIT #	WIDTH
OCCUPANCY SECOND FLOOR:	STAIR #1	104'
OCCUPANCY BUILDING 1: 747 OCC	STAIR #2	66'
TOTAL OCCUPANTS: 747 OCC	STAIR #3	104'
STAIRS = 0.3 IN./OCCUPANT		
0.3/747 OCC = 224.1" REQUIRED		
	TOTAL PROVIDED	274'
	TOTAL REQUIRED	224.1"

REVISIONS:	BUILDING DEPARTMENT COMMENTS:	DRAWING TITLE:
02/14/2020		ENLARGED 2ND FL LIFE SAFETY PLAN AREA A
		SCALE AS NOTED
		ISSUE DATE: 12/16/19
		PROJECT NO: 1906
		SHEET: LS-221


CHECKED BY: LR	DRAWN BY: CV
----------------	--------------

CONSULTANT INFO:

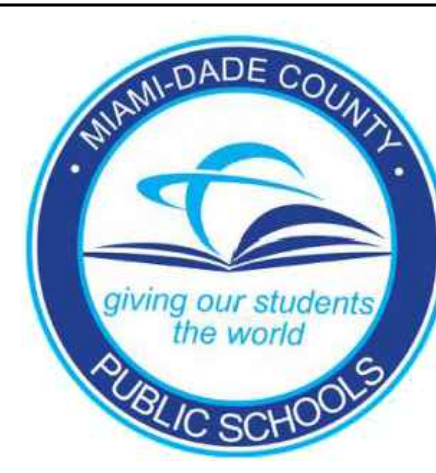

NEW ELEMENTARY SCHOOL (K-5)
VENETIAN PARC WEST
SOUTHWEST 157th AVENUE and 174th STREET
MIAMI, FL. 33187
MDCPS PROJECT No. 01892600

KEY PLAN

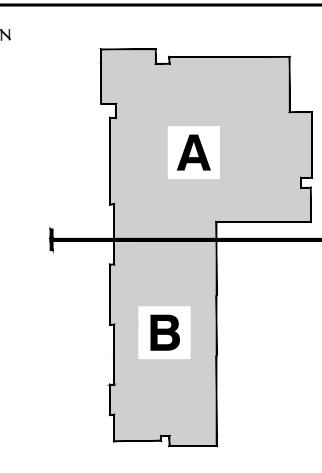

CONSULTANT INFO:

DESIGN & REVISIONS: RAI
PROJECT NO. 1906
PROJECT NAME: VENETIAN PARC WEST
PROJECT ADDRESS: SOUTHWEST 157th AVENUE and 174th STREET
PROJECT CITY: MIAMI, FL 33187
PROJECT STATE: FL
PROJECT COUNTRY: USA

RODRIGUEZ ARCHITECTS INCORPORATED
2121 PONCE DE LEON BLVD. STE 1010
CORAL GABLES, FL 33134
TEL: (305) 448-3373
FAX: (305) 448-3374
A A C - 0 0 1 9 3 3





LIFE-SAFETY LEGEND

- EXIT TRAVEL PATH/FARTHEST POINT-EXIT DISTANCE
- TRAVEL DISTANCE/EXIT TRAVEL PATH (ONLY FARTHEST CONDITION SHOWN FOR CLARITY)
- 1- NUMBER OF OCCUPANTS LEAVING
- 2- REQUIRED WIDTH (inches)
- 3- PROVIDED WIDTH (inches)
- ROOM CAPACITY
- ILLUMINATED EXIT LIGHT (> DIRECTION OF TRAVEL)
- FIRE ALARM HORN / STROBE
- FIRE ALARM SPEAKER/ STROBE
- FIRE ALARM STROBE LIGHT ONLY
- FIRE ALARM PULL STATION
- SMOKE & HEAT DETECTOR
- SMOKE DETECTOR
- HEAT DETECTOR
- MAGNETIC DOOR HOLDER
- CLOCK-SPEAKER SYSTEM
- EMERGENCY-SHOWER / EYE WASH
- FIRE BLANKET
- FIRE BLANKET WITH FIRE EXTINGUISHER
- FIRE ALARM PANEL
- FIRE EXTINGUISHER WALL MOUNTED
- FIRE EXTINGUISHER WALL MOUNTED - CLASS K
- HOSE CABINET W/FEX
- FIRE EXTINGUISHER CABINET-SEMI RECESSED
- FIRE EXTINGUISHER CABINET WALL MOUNTED
- EMERGENCY LIGHT WALL MOUNTED
- EMERGENCY DISCONNECT
- 2X4 EMERGENCY FLUORESCENT LIGHT FIXTURE
- 1X4 EMERGENCY FLUORESCENT LIGHT FIXTURE
- EMERGENCY FLUORESCENT STRIP LIGHT FIXTURE
- EMERGENCY WALL MOUNTED FLUORESCENT STRIP LIGHT FIXTURE
- RECESSED EMERGENCY HIGH HAT LIGHT FIXTURE
- FIRE SPRINKLER HEAD (REFER TO FIRE SPRINKLER DWG'S)
- 3-HOUR WALL SEPARATION RATING
- 2-HOUR WALL SEPARATION RATING
- 1-HOUR WALL SEPARATION RATING
- SMOKE PARTITION SEPARATION
- 1-HR FIRE/SMOKE SEPARATION

FIRE PROTECTION, SUPPRESSION AND DETECTION SYSTEM REQUIREMENTS

	REQUIRED	PROVIDED
FIRE SPRINKLER	YES	YES
FIRE ALARM	YES	YES
KITCHEN FIRE SUPPRESSION	YES	YES
FIRE EXTINGUISHERS	YES	YES
SMOKE ALARMS	YES	YES
HEAT DETECTORS	YES	YES

FLOOR PLAN GENERAL NOTES


- ALL NEW BUILDINGS ARE FULLY SPRINKLED. ALL COVERED WALKWAYS (IF PROVIDED) ARE OF NON-COMBUSTIBLE CONSTRUCTION AND ARE NOT SPRINKLED.
- ALL FIRE PROTECTION SPRINKLERS SHALL BE CONCEALED TYPE WITH FINISH COVER TO MATCH ADJACENT CEILING. EXPOSED CEILING AREAS TO HAVE STANDARD UPRIGHT HEADS.
- SEE REFLECTED CEILING DRAWINGS FOR REMAINDER OF LIGHTING.
- ALL FIRE EXTINGUISHERS SHALL BE INSTALLED TO MEET ACCESSIBILITY, TYPE AND SIZE REQUIREMENTS PER APPLICABLE CODES.
- ALL FIRE ALARM DEVICES IN OCCUPIED, CIRCULATION AND FINISHED SPACES AS DESIGNATED BY ARCHITECT SHALL HAVE WHITE FINISH.
- ALL EXIT SIGNS IN ADMINISTRATIVE, ASSEMBLY AND CIRCULATION AREAS SHALL BE CLEAR ACRYLIC (EDGE LIT) WITH BRUSHED NICKEL FINISH AND GREEN LETTERS (STANDARD).
- ALL SPACES OVER 1,000 NSF OR GREATER THAN 50 OCCUPANTS SHALL BE PROVIDED WITH PANIC HARDWARE AT ALL REQUIRED EXIT DOORS/GATES AND MAXIMUM OCCUPANT SIGNS AS REQUIRED.
- MINIMUM FLAME AND SMOKE SPREAD RATING FOR ALL FINISHES SHALL BE IN ACCORDANCE WITH 2017 FBC 6TH ED. TABLE 803.11.
- ALL REQUIRED EXIT DOORS AND STAIR ACCESS DOORS TO BE PROVIDED WITH PANIC HARDWARE IN ACCORDANCE WITH 2017 FBC 6TH ED. AND 2017 FFPC 6TH ED.
- AREAS OF REFUGE HAVE BEEN PROVIDED/DESIGNATED AT EACH STAIR SECOND FLOOR ACCESS PLATFORM IN ACCORDANCE WITH 2017 FBC 6TH ED. / 2017 FFPC 6TH ED.

STAIR REQUIREMENTS

BUILDING No. 01	EXIT #	WIDTH
OCCUPANCY SECOND FLOOR:	STAIR #1	104"
OCCUPANCY BUILDING 1: 747 OCC	STAIR #2	66"
TOTAL OCCUPANTS: 747 OCC	STAIR #3	104"
STAIRS = 0.3 IN./OCCUPANT		
0.3/747 OCC = 224.1" REQUIRED		
	TOTAL PROVIDED	274"
	TOTAL REQUIRED	224.1"


CHECKED BY: LR. DRAWN BY: CV.

CONSULTANT INFO:

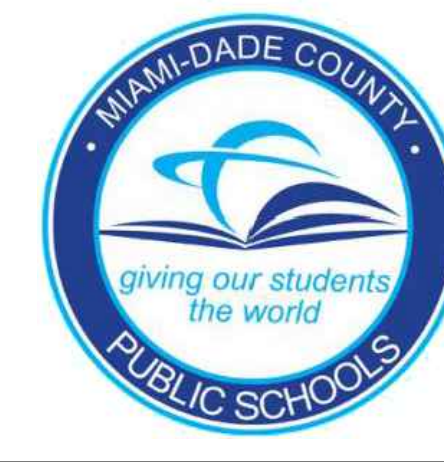


NEW ELEMENTARY SCHOOL (K-5)
VENETIAN PARC WEST
SOUTHWEST 157th AVENUE and 174th STREET
MIAMI, FL. 33187
MDCPS PROJECT No. 01892600

KEY PLAN

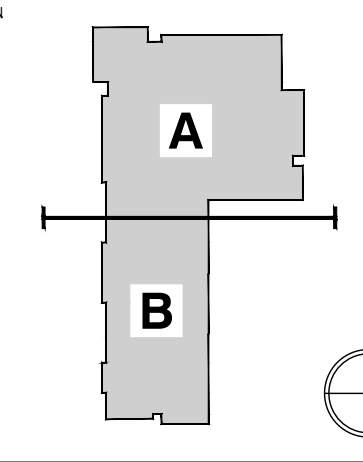

CONSULTANT INFO:

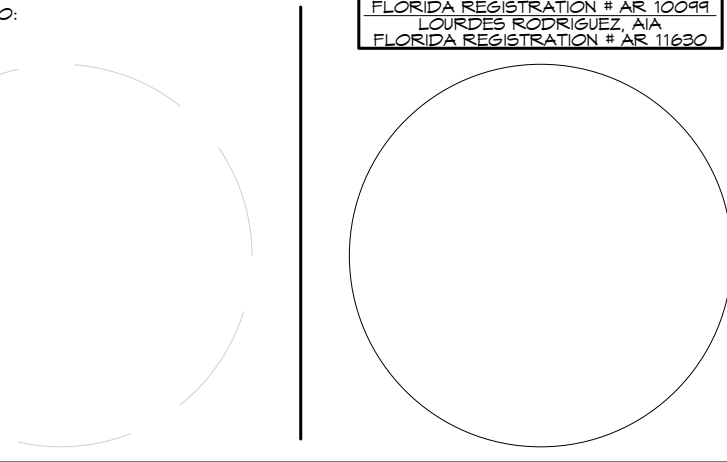

RODRIGUEZ ARCHITECTS INCORPORATED
2121 PONCE DE LEON BLVD. STE 1010
CORAL GABLES, FL. 33134
TEL: (305) 448-3373
FAX: (305) 448-3374
A A C — 0 0 1 9 3 3



REVISIONS:
02.14.2020 BUILDING DEPARTMENT COMMENTS

DRAWING TITLE:
ENLARGED 2ND FL LIFE SAFETY PLAN AREA B
SCALE AS NOTED
ISSUE DATE: 12/16/19
PROJECT NO: 1906
SHEET: **LS-222**

SITE PLAN GENERAL NOTES

- ALL SITE ADAPTATION WORK REQUIRED TO CONSTRUCT BUILDINGS SHALL BE IN ACCORDANCE WITH THE FOLLOWING CODES OF RECORD:
2017 FLORIDA BUILDING CODE, 6TH EDITION WITH APPLICABLE REVISIONS
2017 FLORIDA FIRE PREVENTION CODE, 6TH EDITION
- CONTRACTOR SHALL CLEAR AND PREPARE THE SITE TO RECEIVE NEW BUILDING AND WALKWAY PAD. FILL SHALL BE COMPACTED TO MINIMUM 3,000 PSF AS PRELIMINARY BASIS OF DESIGN TO BE CONFIRMED BY GEO-TECHNICAL REPORT. GENERAL CONTRACTOR SHALL SUBMIT TO OWNER GEO-TECHNICAL REPORTS CONFIRMING THE REQUIRED COMPACTION PRIOR TO CONSTRUCTION OF BUILDING. CONTRACTOR SHALL PREPARE THE SITE TO RECEIVE NEW FOUNDATIONS AS REQUIRED BY THE GEOTECHNICAL REPORT.
- BUILDING SHALL BE ACCESSIBLE. ALL WALKWAYS, RAMPS, AND STAIRS LEADING TO THE BUILDING SHALL BE IN COMPLIANCE WITH FLORIDA ACCESSIBILITY CODE. THERE SHALL BE NO CHANGES IN WALKWAY ELEVATION GREATER THAN 1/4".
- CONTRACTOR SHALL REROUTE AND REPAIR ANY IRRIGATION IN CONFLICT WITH PROPOSED SCOPE OF WORK. CONTRACTOR SHALL RE-GRADE AND RE-SOD ALL AREAS AFFECTED BY NEW WORK.
- GENERAL CONTRACTOR SHALL PROVIDE 6 FT. CHAIN LINK CONSTRUCTION FENCE AS REQUIRED TO CONTROL AND SEPARATE PEDESTRIAN TRAFFIC FROM CONSTRUCTION ACTIVITIES. EXACT LOCATION AND CONFIGURATION SHALL BE COORDINATED WITH DISTRICT REPRESENTATIVE AT PRE-CONSTRUCTION MEETINGS.
- FOR EXISTING SITE CONDITIONS AND IMPROVEMENTS REFERENCE ATTACHED SITE SURVEY.
- GENERAL CONTRACTOR SHALL COORDINATE AND SUBMIT SIGNED AND SEALED SHOP DRAWINGS AND CALCULATIONS FOR ALL SPECIALTY ITEMS TO BE APPROVED BY DESIGN ENGINEER/ARCHITECT OF RECORD FOR DESIGN INTENT AS PER CHIEF PLANS EXAMINER AND BUILDING OFFICIAL AND FBC 104-2 SPECIALTY ENGINEERING ITEMS INCLUDE BUT ARE NOT LIMITED TO: FENCING, SIGNAGE, SITE LIGHTING, ETC.
- ALL ENGINEERED SHOP DRAWINGS AND CALCULATIONS SIGNED AND SEALED (WHICH USE ASSE 7-10 AS CRITERION FOR WIND LOADS).
- THE CONTRACTOR SHALL BE RESPONSIBLE FOR SAFETY DURING DEMOLITION AND CONSTRUCTION. THE CONTRACTOR SHALL BE FAMILIAR WITH AND BE RESPONSIBLE FOR ADHERENCE TO ALL GOVERNING REGULATIONS.
- DURING THE ENTIRE CONSTRUCTION PERIOD, IT SHALL BE THE RESPONSIBILITY OF THE CONTRACTOR TO MAINTAIN CONDITIONS AT THE JOB SITE SO AS TO MEET IN ALL RESPECTS THE REQUIREMENTS OF THE OCCUPATIONAL SAFETY AND HEALTH ACT (OSHA). THIS PROVISION SHALL COVER THE CONTRACTOR'S EMPLOYEES AND ALL OTHER PERSONS WORKING UPON OR VISITING THE SITE. TO THIS END, THE CONTRACTOR SHALL INFORM HIMSELF AND HIS REPRESENTATIVES OF OSHA STANDARDS.
- CONTRACTOR SHALL FIELD VERIFY ALL CONDITIONS AND DIMENSIONS FOR EXACT EXTENT OF DEMOLITION AND NOTIFY ARCHITECT OF ANY DISCREPANCIES BEFORE PROCEEDING W/ WORK. CONTRACTOR SHALL BE RESPONSIBLE FOR ANY CONFLICTS THAT MAY HAVE BEEN AVOIDED THEREBY.
- CONTRACTOR IS TO REFER TO CIVIL, LANDSCAPE, MECHANICAL, PLUMBING, FIRE PROTECTION AND ELECTRICAL DRAWINGS FOR FULL EXTENT OF WORK.
- CONTRACTOR SHALL COORDINATE ALL WORK WITH THE OWNER SO THAT THE OWNER'S AND SURROUNDING PROPERTY OPERATIONS/ACTIVITIES ARE NOT INTERRUPTED. IF ANY ACTIVITY IS TO BE INTERRUPTED, I.E. NORMAL WORKING CONDITIONS, TELEPHONE, ELECTRICITY, WATER OR ANY OTHER UTILITY NOT MENTIONED, CONTRACTOR IS TO OBTAIN WRITTEN PERMISSION FROM THE OWNER AUTHORIZING SUCH INTERRUPTION.
- ITEMS TO BE REMOVED IN DEMOLITION AREAS ARE TO BE VERIFIED BY FIELD INSPECTION. IT IS THE INTENT TO REMOVE EXISTING FEATURES AS REQUIRED TO PREPARE THE AREA FOR CONSTRUCTION. IF A FEATURE OF REMOVED IS NOT SHOWN IT DOES NOT RELIEVE THE CONTRACTOR OF THE RESPONSIBILITY OF REMOVING SUCH A FEATURE OR ENTITLE HIM TO AN EXTRA FOR THE REMOVAL OF SUCH FEATURE.
- REPAIR ALL PAVED AND WALK SURFACES DAMAGED BY CONSTRUCTION TO LIKE NEW WITH MATERIAL TO MATCH ADJACENT.
- FOR ALL GRADING OF SITE SEE CIVIL DRAWINGS.
- CONTRACTOR SHALL LOCATE, CLEARLY MARK AND COORDINATE ALL UNDERGROUND UTILITIES PRIOR TO COMMENCING WORK.
- CONTRACTOR SHALL COORDINATE ALL PHASING WITH DISTRICT REPRESENTATIVE.
- ALL WIRE FABRIC MESH TO BE VINYL COATED 2" MESH (COLOR SELECTED BY ARCHITECT). ALL FENCE MATERIAL TO BE ALIED #540 OR EQUAL CONFORMING TO CLFMI AND DISTRICT SPECIFICATIONS. ALL FENCING MATERIAL TO BE GALVANIZED AND COATED UNLESS NOTED OTHERWISE. ALL FENCES ARE TO BE DESIGNED AND CONSTRUCTED IN ACCORDANCE WITH ALL APPLICABLE CODES INCLUDING CURRENT EDITION OF FLORIDA BUILDING CODE. MINIMUM WIND SPEED OF 166 MILES PER HOUR AND EXPOSURE CATEGORY "C" TO BE USED IN DESIGN.
- ALL SITE BOLLARDS ARE TO BE PROVIDED WITH DECORATIVE COVER EQUAL TO RELIANCE FOUNDRY, LTD. MODEL R-7172 WITH COLOR TO BE SELECTED FROM FULL RANGE OF COLORS BY ARCHITECT/OWNER.
- ALL SITE LIGHTING POLES TO BE PROVIDED WITH ADDITIONAL CONVENIENCE EXTERIOR GRADE COVERED DUPLEX OUTLET MOUNTED AT BASE.
- ALL PROPOSED STRUCTURES WHICH INCLUDE SITE LIGHTING POLES, FENCES, WALLS, ETC. MUST COMPLY WITH THE FOLLOWING: FBC 1620.2, FBC 1622.2-1, FBC 1621.1 (ASSE 7-10) & FBC 1621.2 (ASSE 7-10).
- CONTRACTOR SHALL BE RESPONSIBLE FOR ALL ASSOCIATED CIVIL WORK RELATED TO BOTH THE ON AND OFF SITE CONDITIONS NOT GRAPHICALLY SHOWN ON THIS ARCHITECTURAL SITE PLAN.

SITE PLAN LEGEND

- CONTROL POINT FROM PROPERTY LINE
- PROJECT LIMIT LINE

PARKING CALCULATIONS


PARKING REQUIREMENTS (AS PER DISTRICT AND ZONING CODE)	
FACULTY AND STAFF (56 @ 1:1)	56 SPACES
SUB-TOTAL SPACES	56 SPACES
VISITORS (800 @ 100:1)	8 SPACES
TOTAL SPACES REQUIRED	64 SPACES
ADA SPACES REQUIRED 101-150 (PER 2017 FBC ACCESSIBILITY CODE, 6TH ED. TABLE 208.2)	5 SPACES
PROVIDED PARKING SPACES:	
FACULTY AND STAFF	82 SPACES
RECEIVING/FOOD SERVICE	2 SPACES
VISITORS	12 SPACES
ADA SPACES PROVIDED	5 SPACES
TOTAL NUMBER OF SPACES PROVIDED	101 SPACES

NOTE:
ALL SPACES PROVIDED ARE ON-SITE ONLY.

QUEUING CALCULATIONS

PARKING REQUIREMENTS (MIAMI-DADE COUNTY ZONING CODE)	
ELEMENTARY SCHOOL	5 SPACES
TOTAL REQUIRED ONSITE	110 LF (22 LF / VEHICLE)
QUEUING LENGTH	732 LF (22 LF / VEHICLE)
TOTAL PROVIDED ONSITE	732 LF

1 SITE PLAN
A-100 Scale: 1"=30'-0"

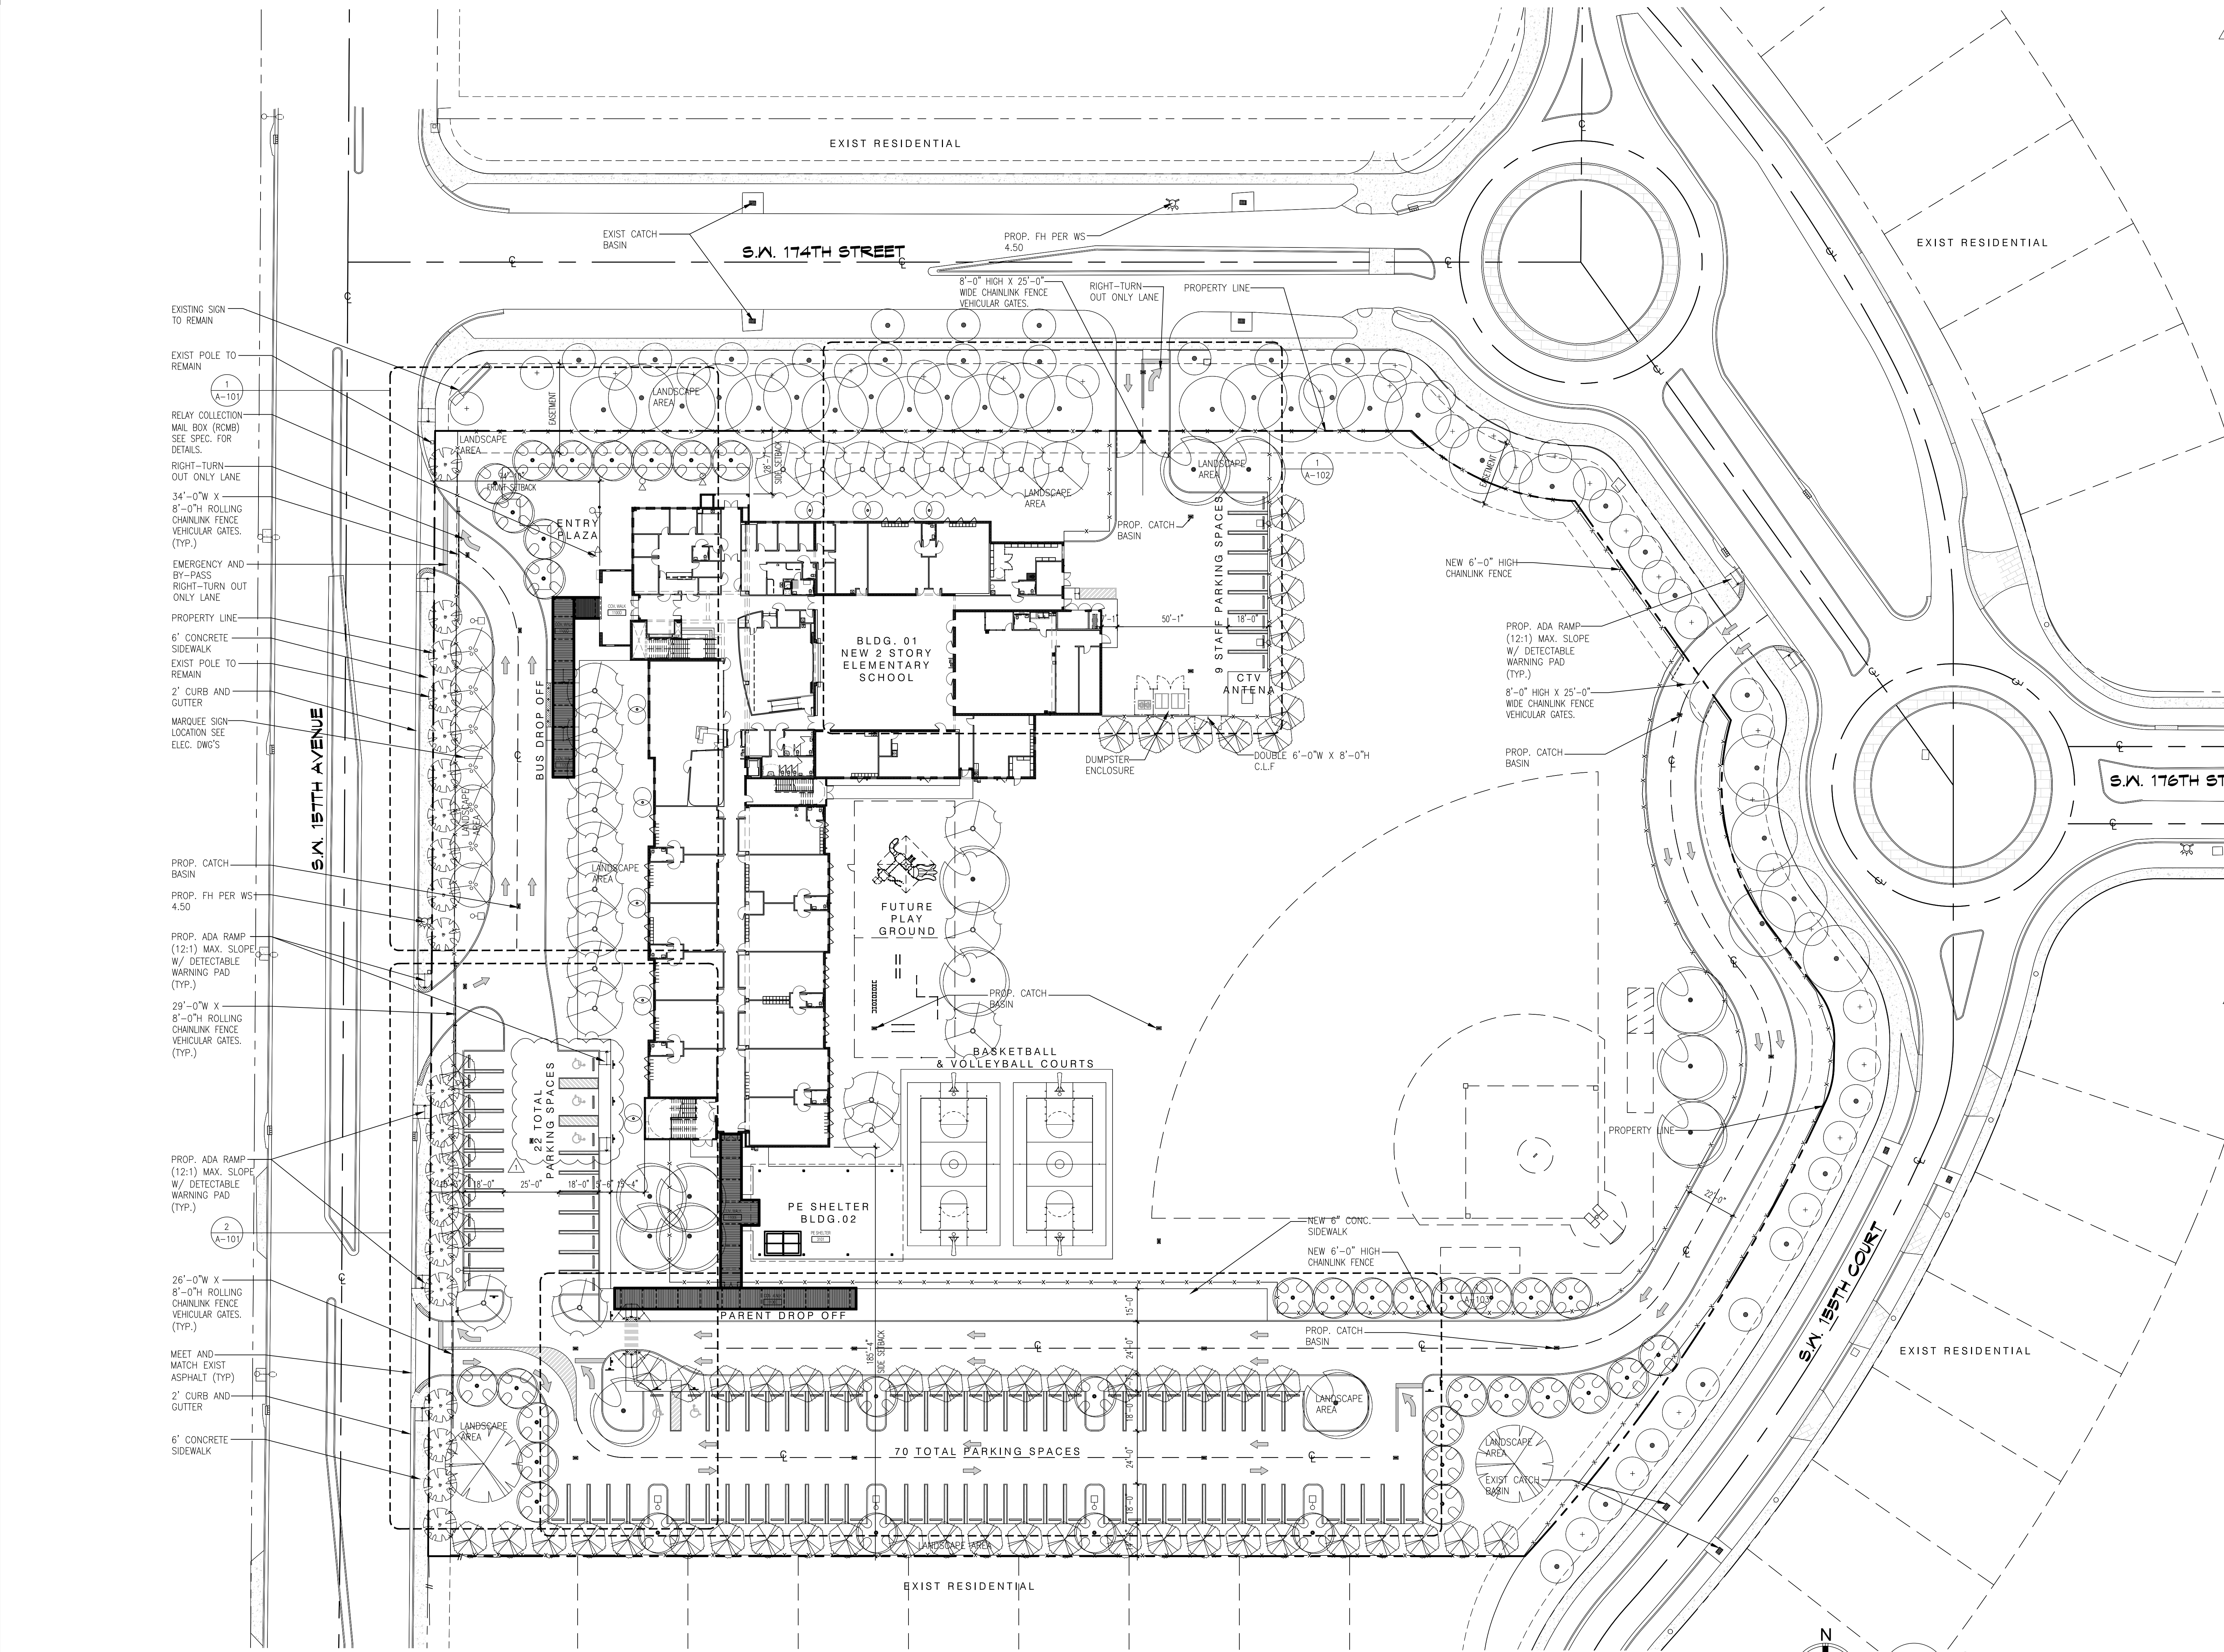

CHECKED BY:
LR

DRAWN BY:
C.V.

CONSULTANT INFO:

NEW ELEMENTARY SCHOOL (K-5)
VENETIAN PARC WEST
SOUTHWEST 157th AVENUE and 174th STREET
MIAMI, FL. 33187
MDCPS PROJECT No. 01892600

KEY PLAN




CONSULTANT INFO:

RODRIGUEZ ARCHITECTS INCORPORATED
2121 PONCE DE LEON BLVD. STE. 1010
CORAL GABLES, FL. 33134
TEL: (305) 448-3373
FAX: (305) 448-3374
A A C — 0 0 1 9 3 3


REVISIONS:

02142020	BUILDING DEPARTMENT COMMENTS
----------	------------------------------



DRAWING TITLE:
SITE PLAN
SCALE AS NOTED
ISSUE DATE:
12/16/19
PROJECT NO:
1906
SHEET:
A-100

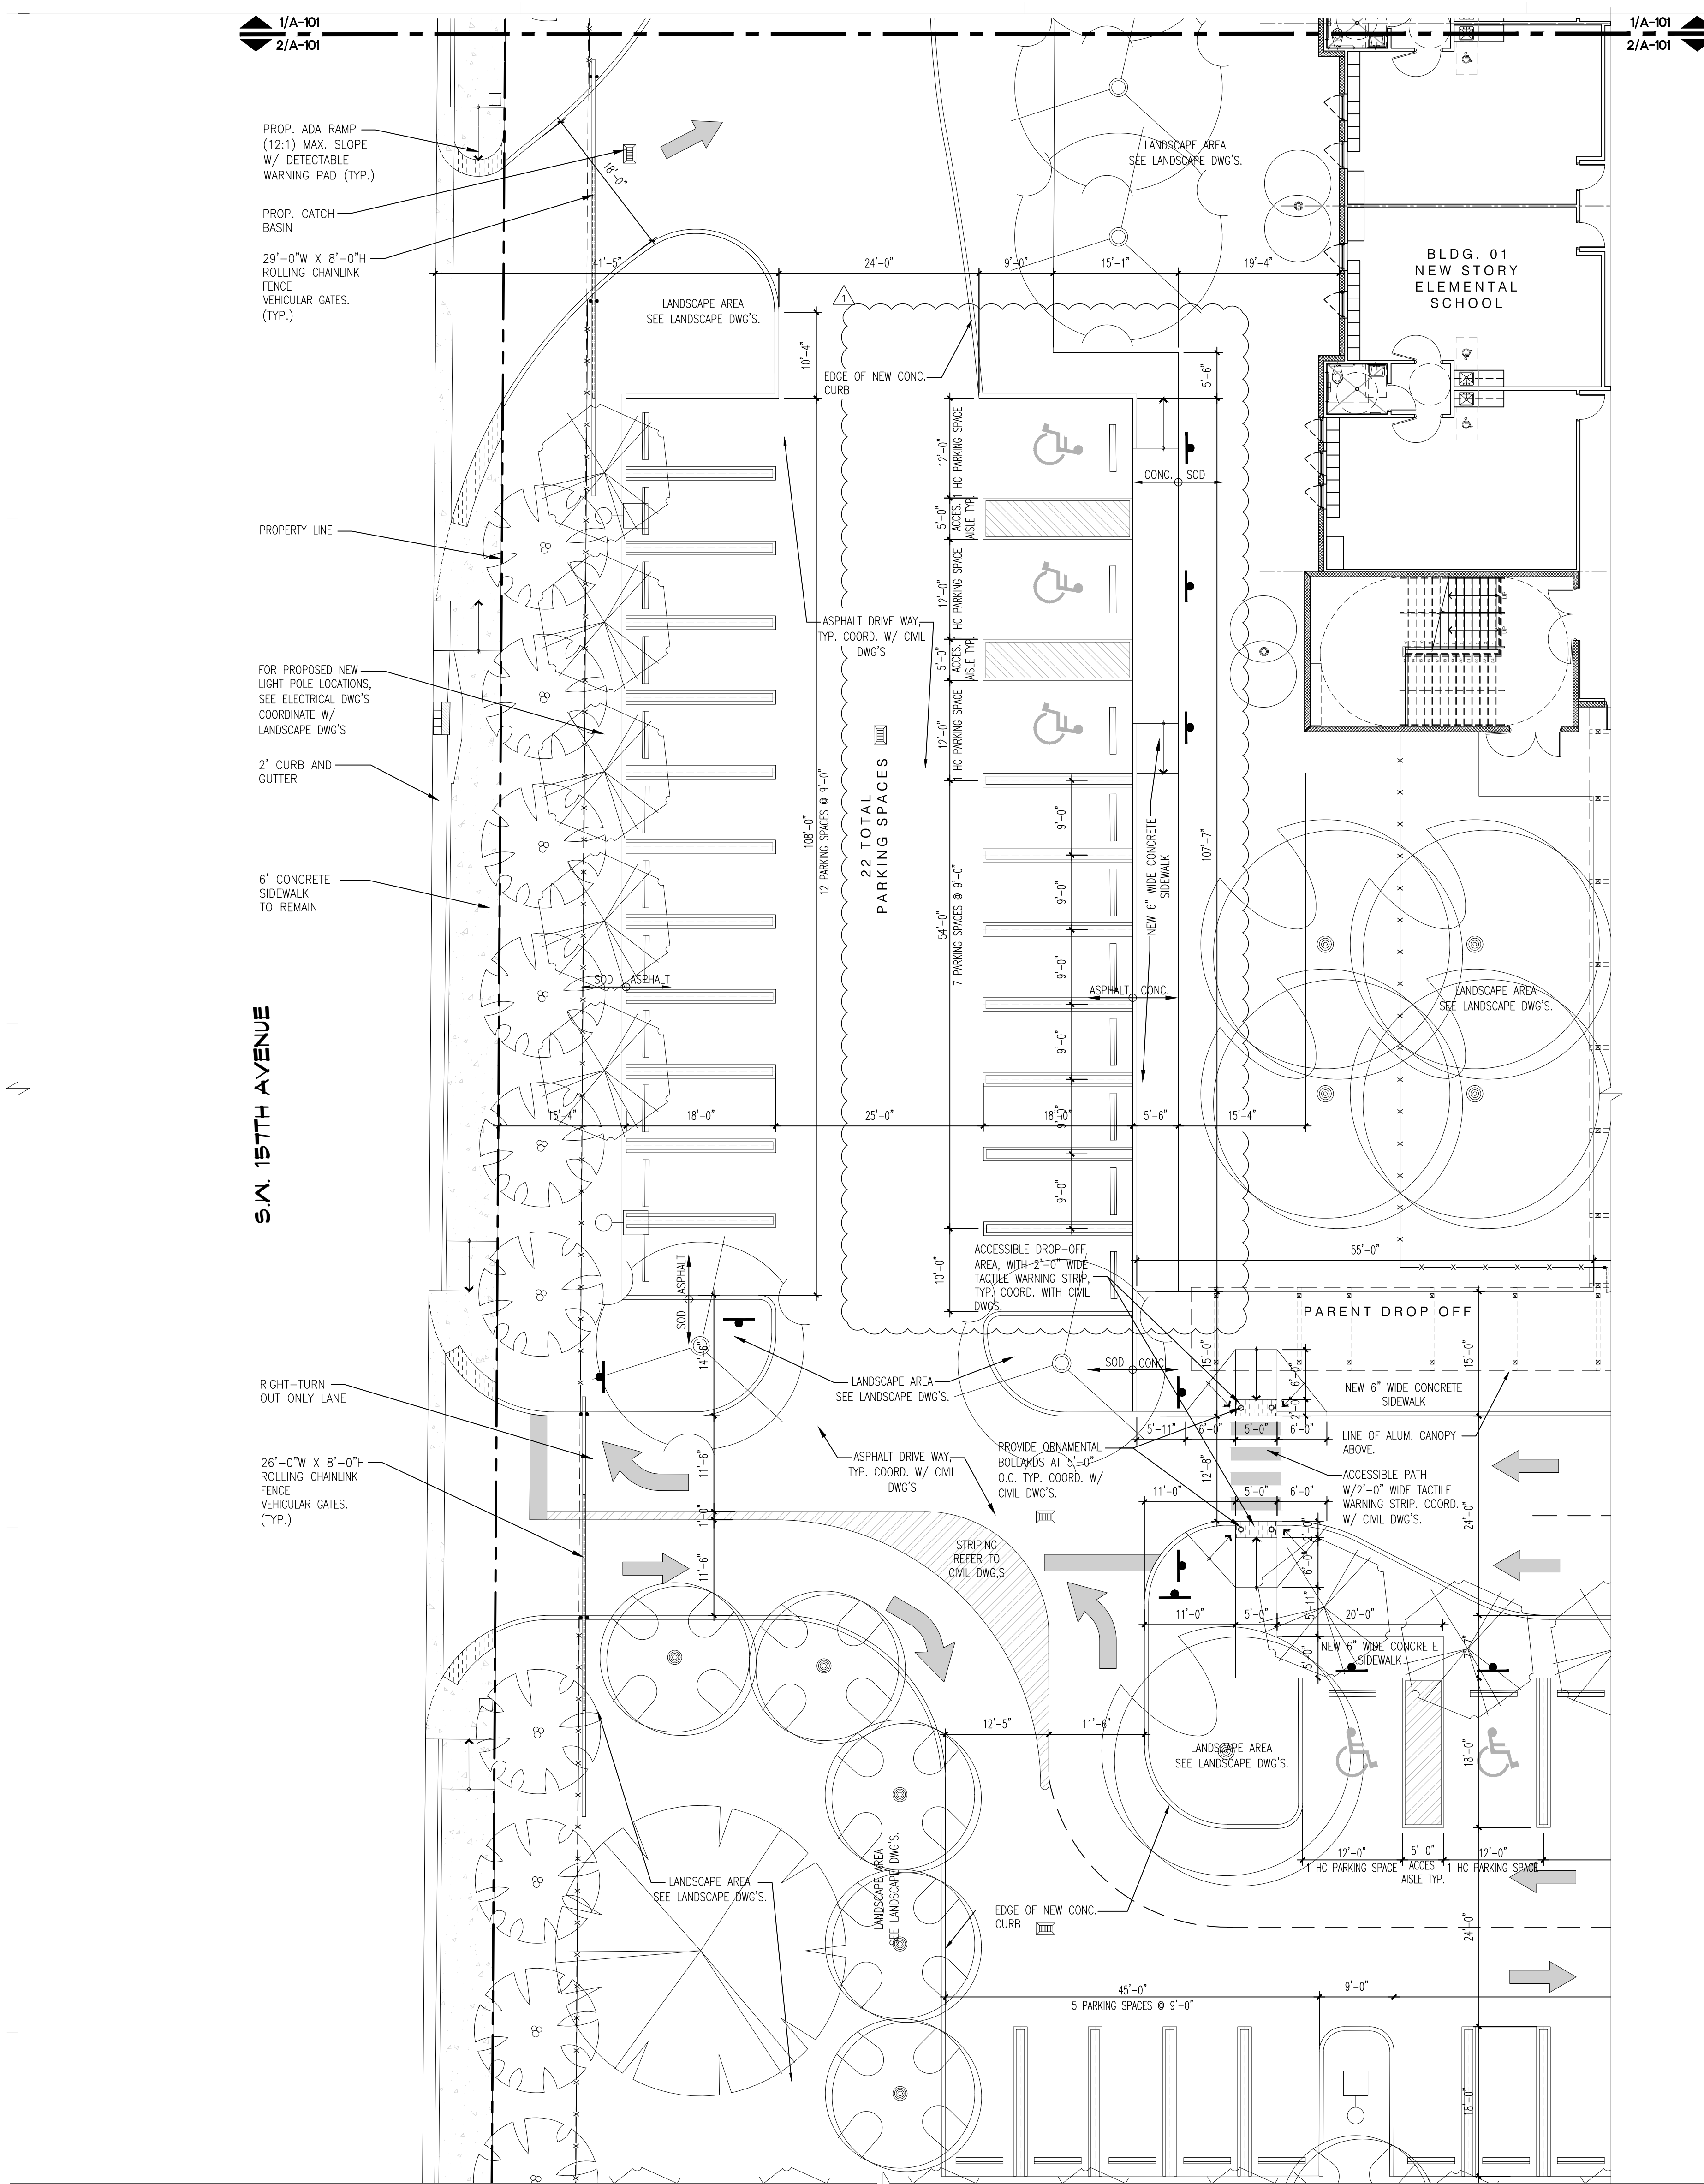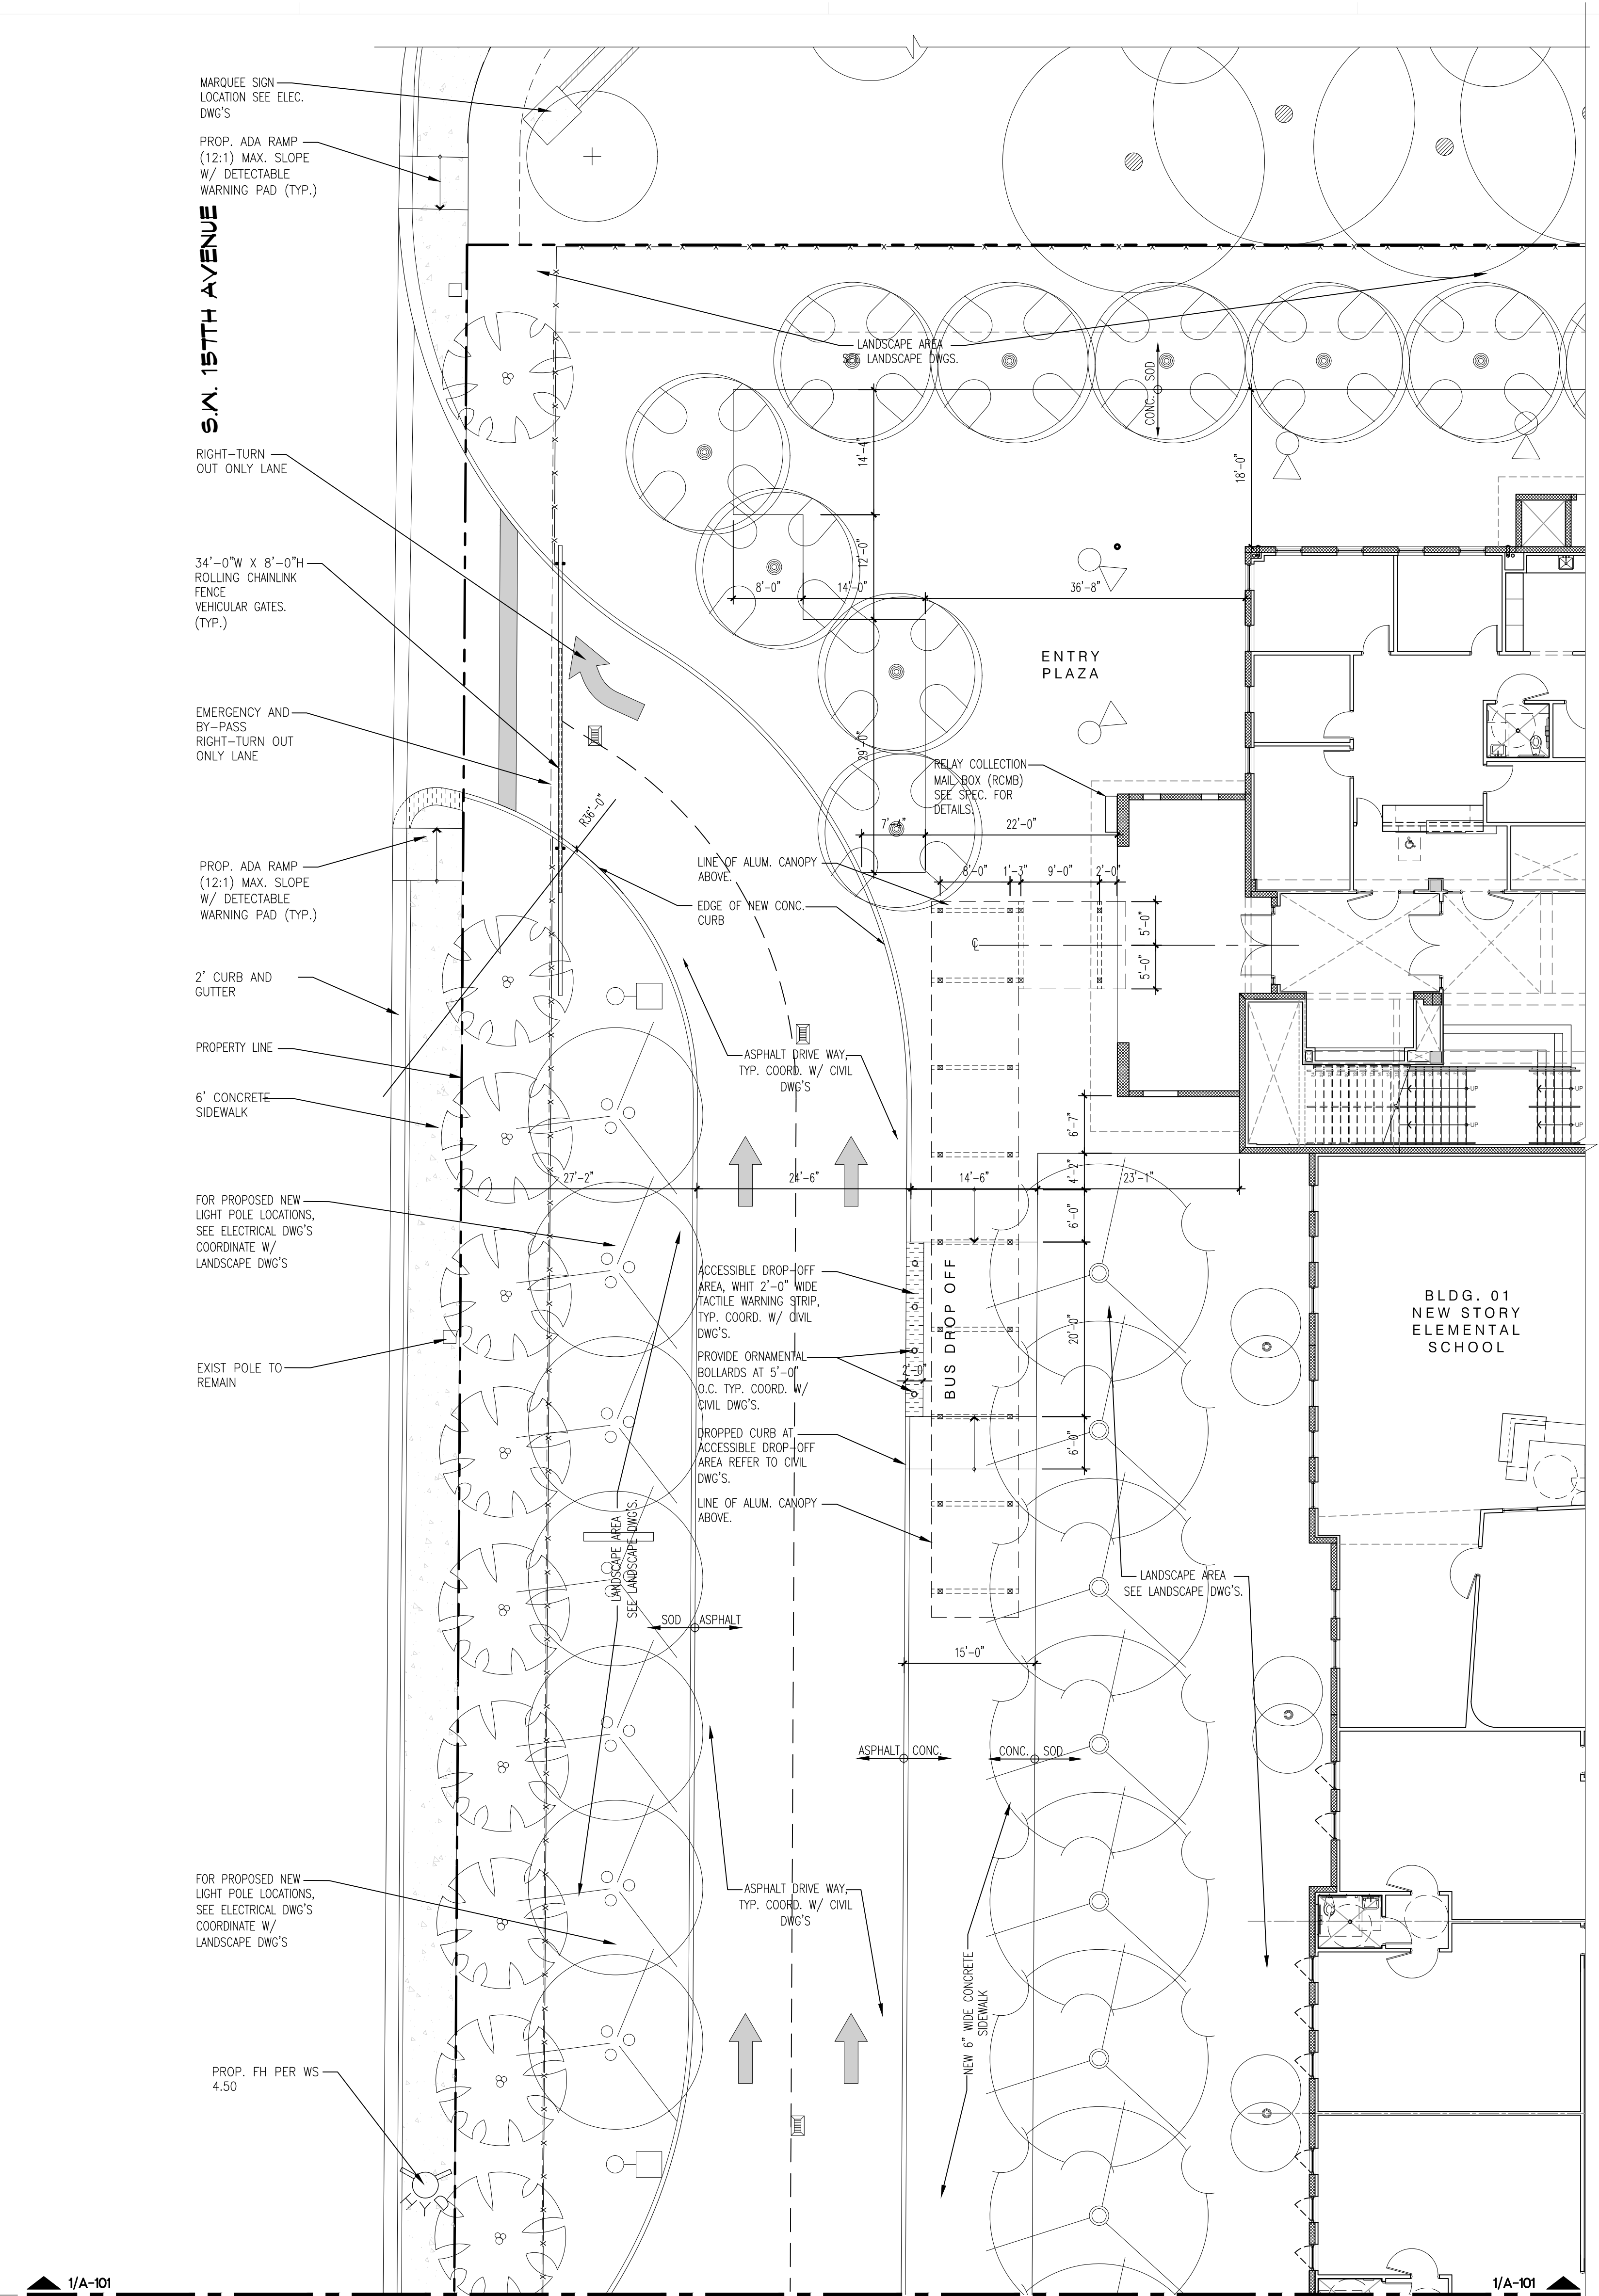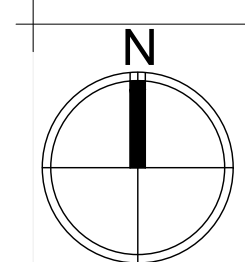


2 ENLARGED SITE PLAN - PARKING AREA
A-101 Scale: 3/32" = 1'-0"

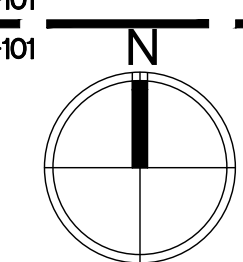

1 ENLARGED SITE PLAN - ENTRY PLAZA/BUS DROP-OFF AREA

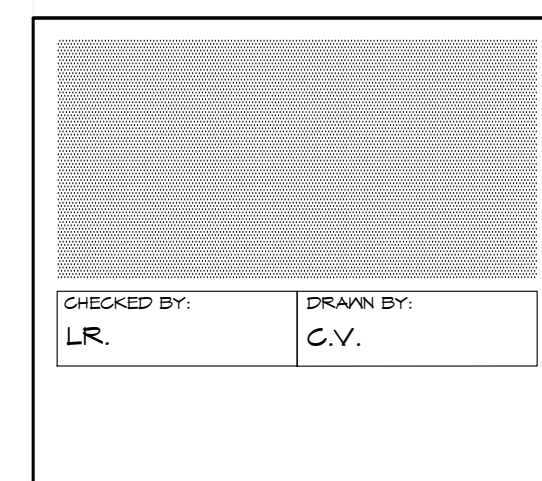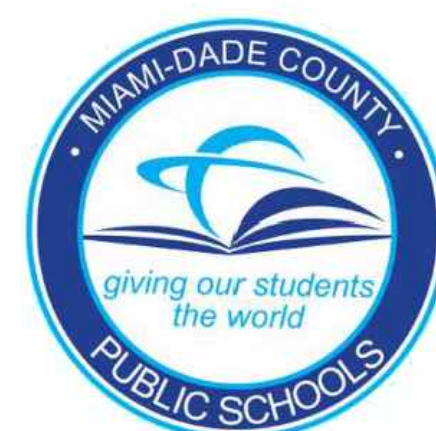


NEW ELEMENTARY SCHOOL (K-5)
VENETIAN PARC WEST
 SOUTHWEST 157th AVENUE and 174th STREET
 MIAMI, FL. 33187
 MDCPS PROJECT No. 01892600

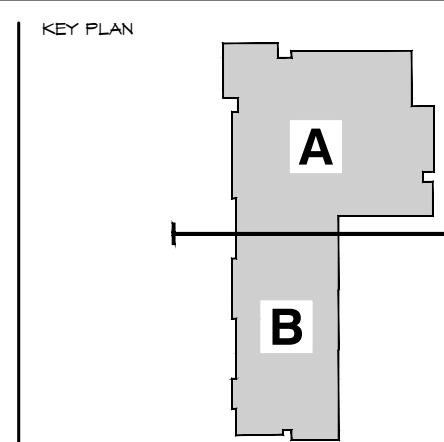

CONSULTANT INFO



**RODRIGUEZ
ARCHITECTS
INCORPORATED**
2121 PONCE DE LEON BLVD. STE. 1010
CORAL GABLES, FL. 33134
TEL: (305) 448-3373
FAX: (305) 448-3374

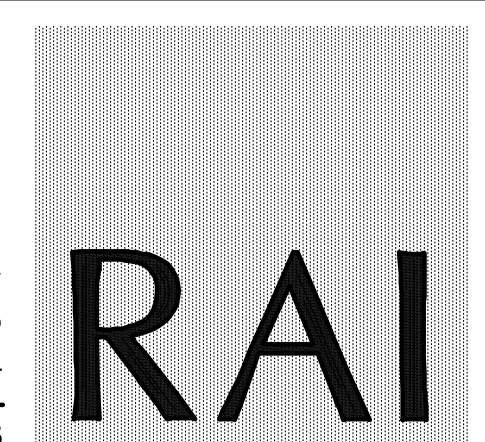

REVISIONS:

	DATE	BUILDING DEPARTMENT COMMENTS

DRAWING TITLE:



**ENLARGED
SITE PLAN
PARKING AREA**


SCALE AS NOTED

ISSUE DATE: 12.16.19	PROJECT NO. 1906
-------------------------	---------------------

SHEET:


A-101

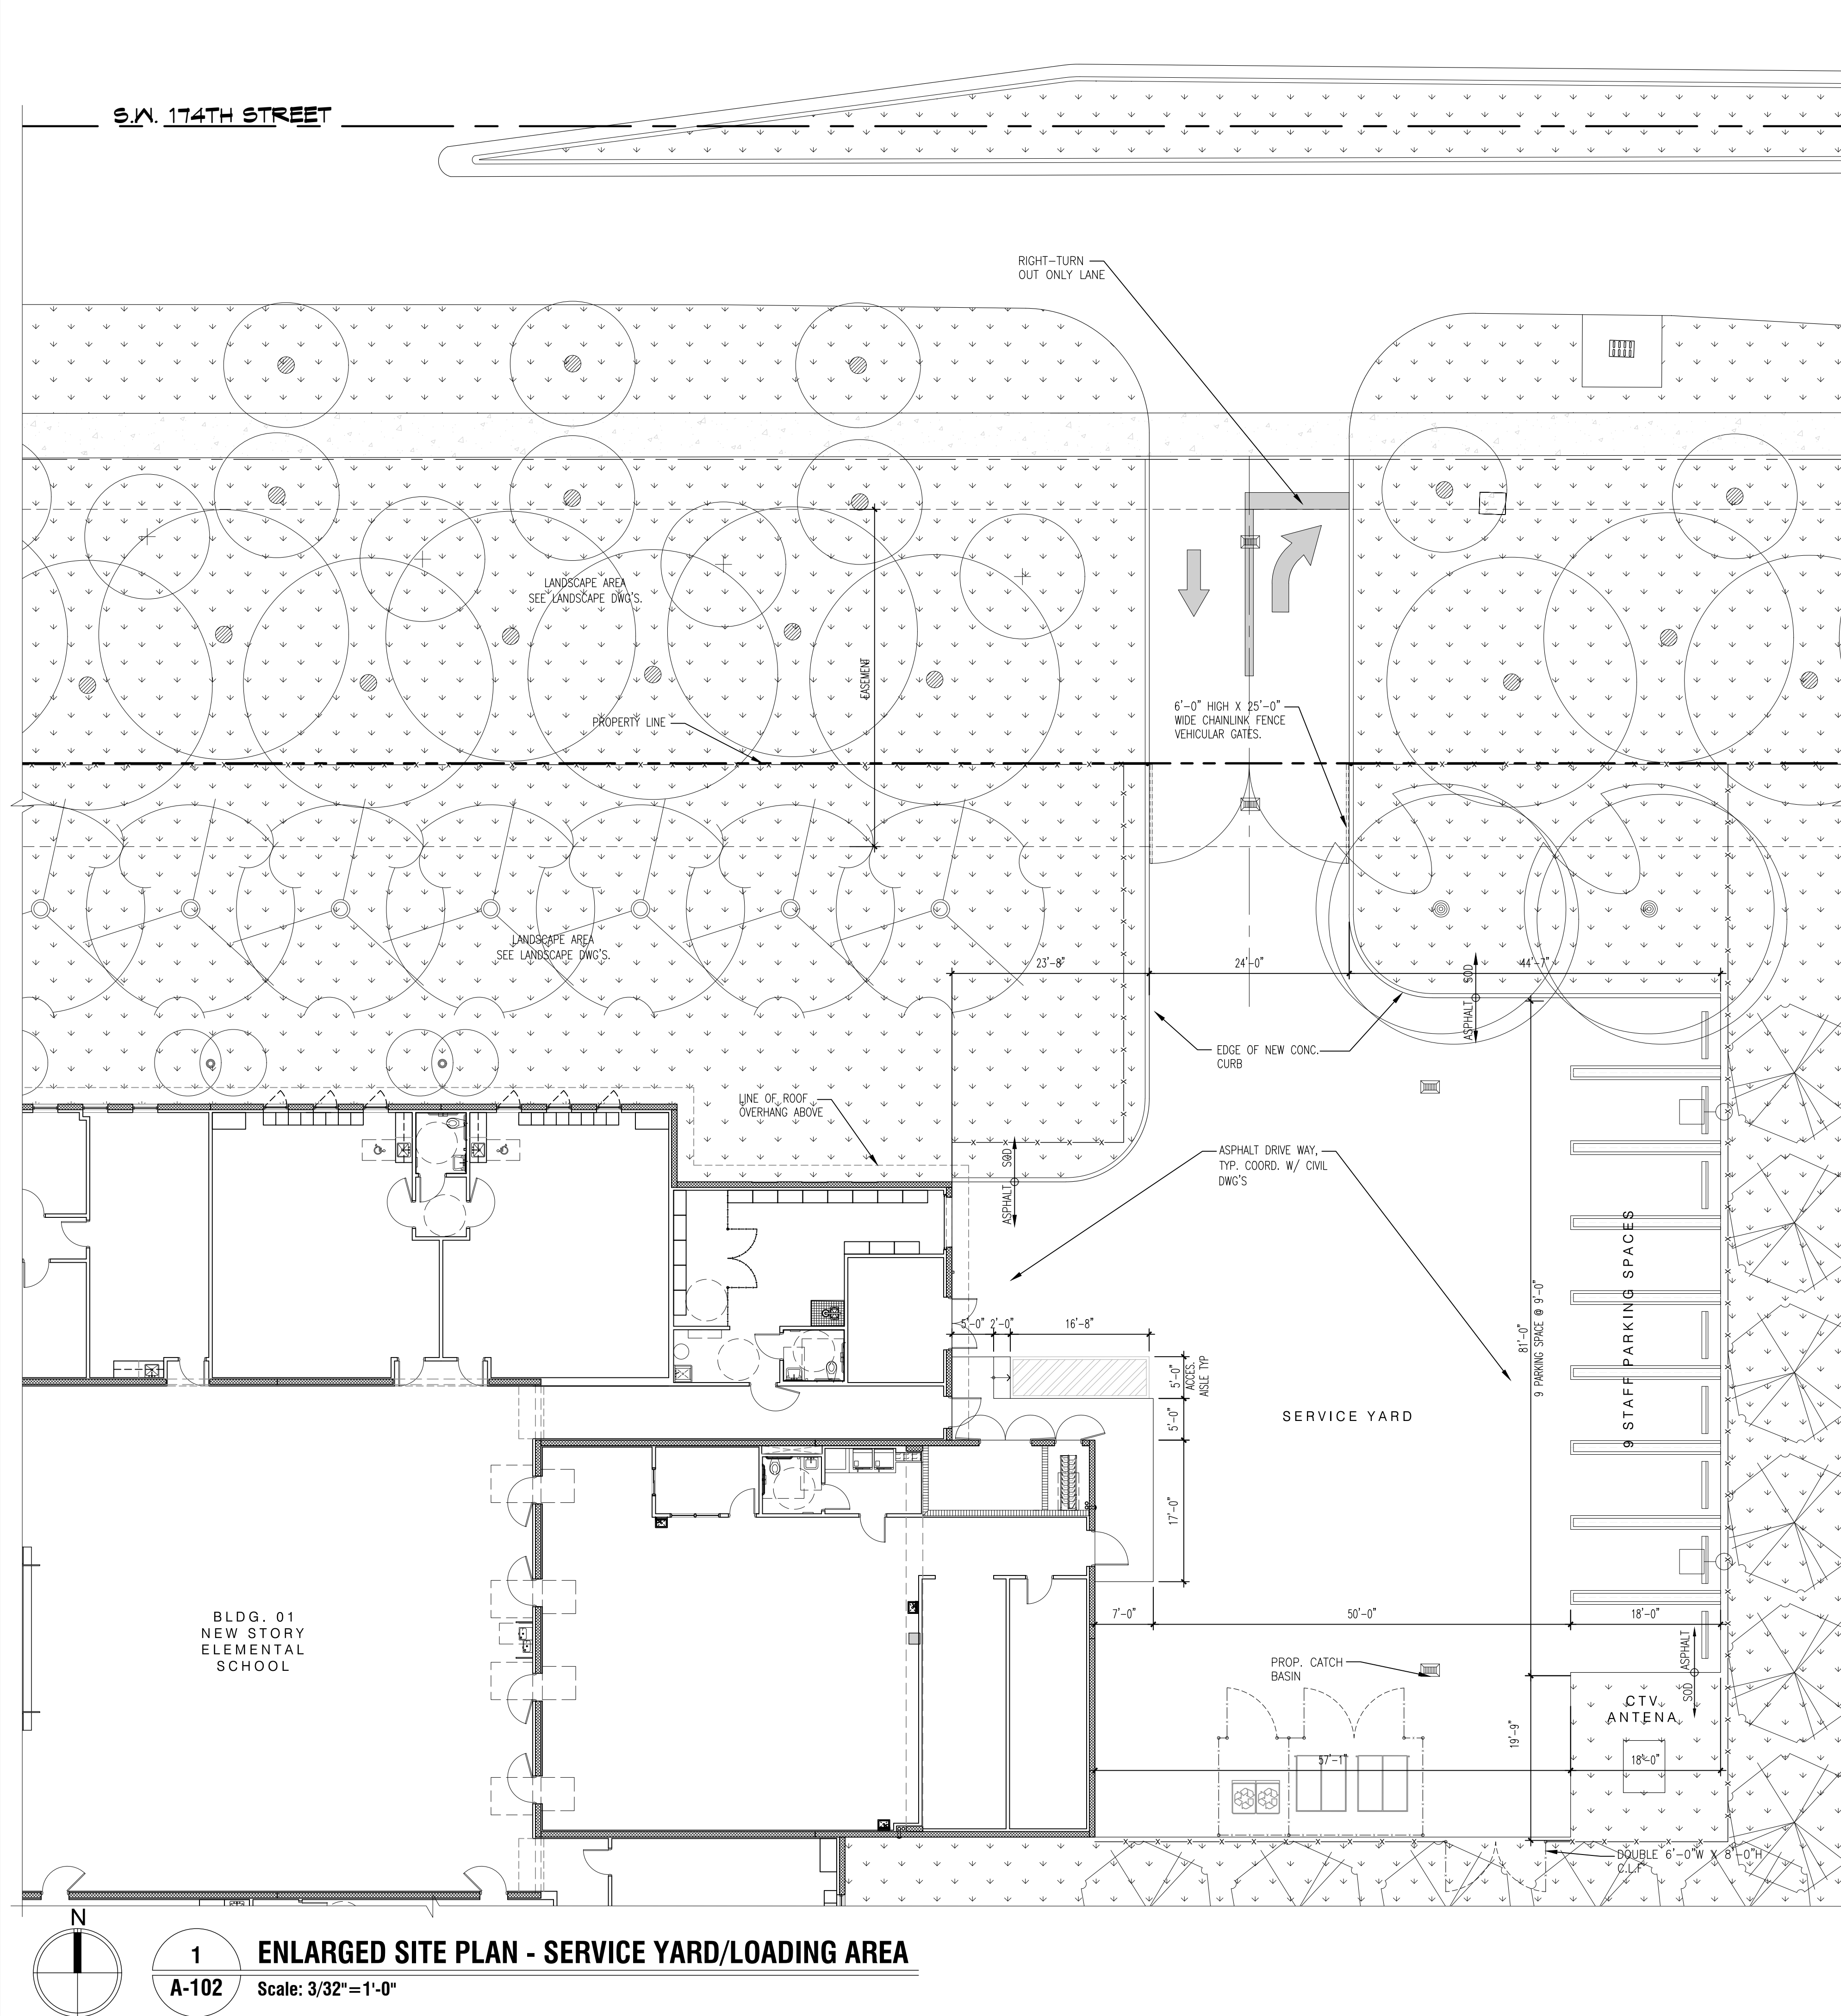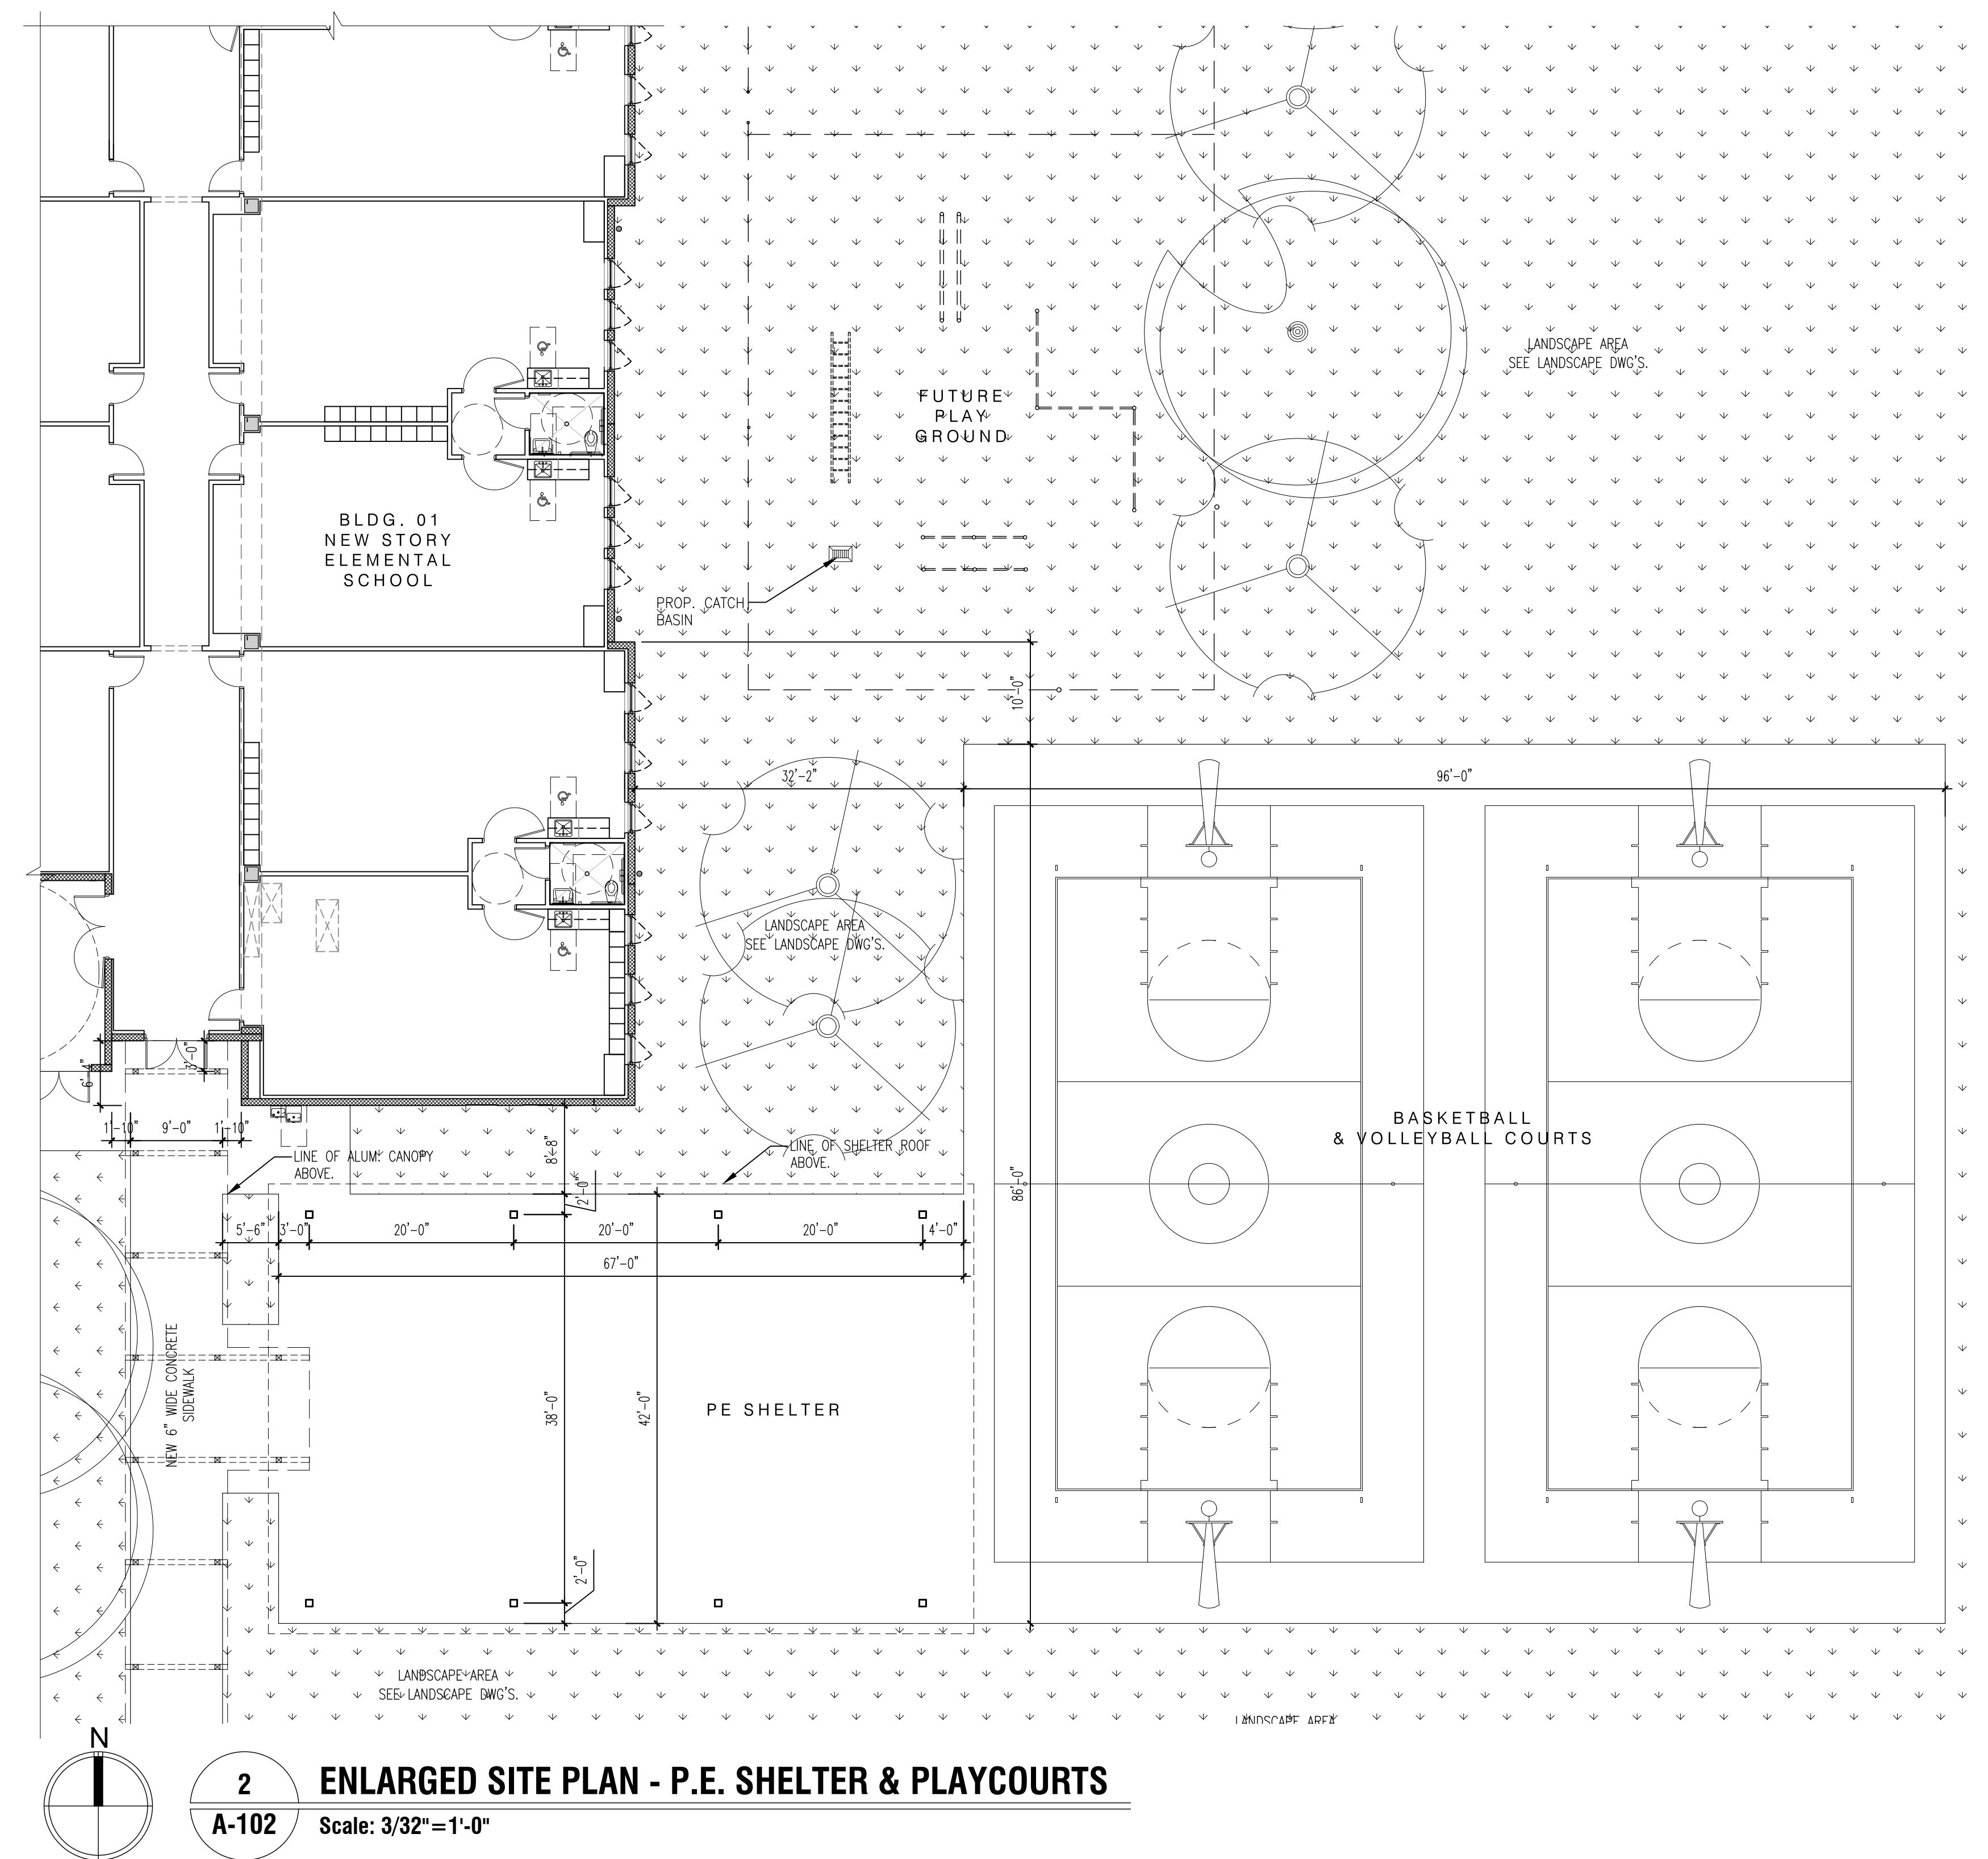

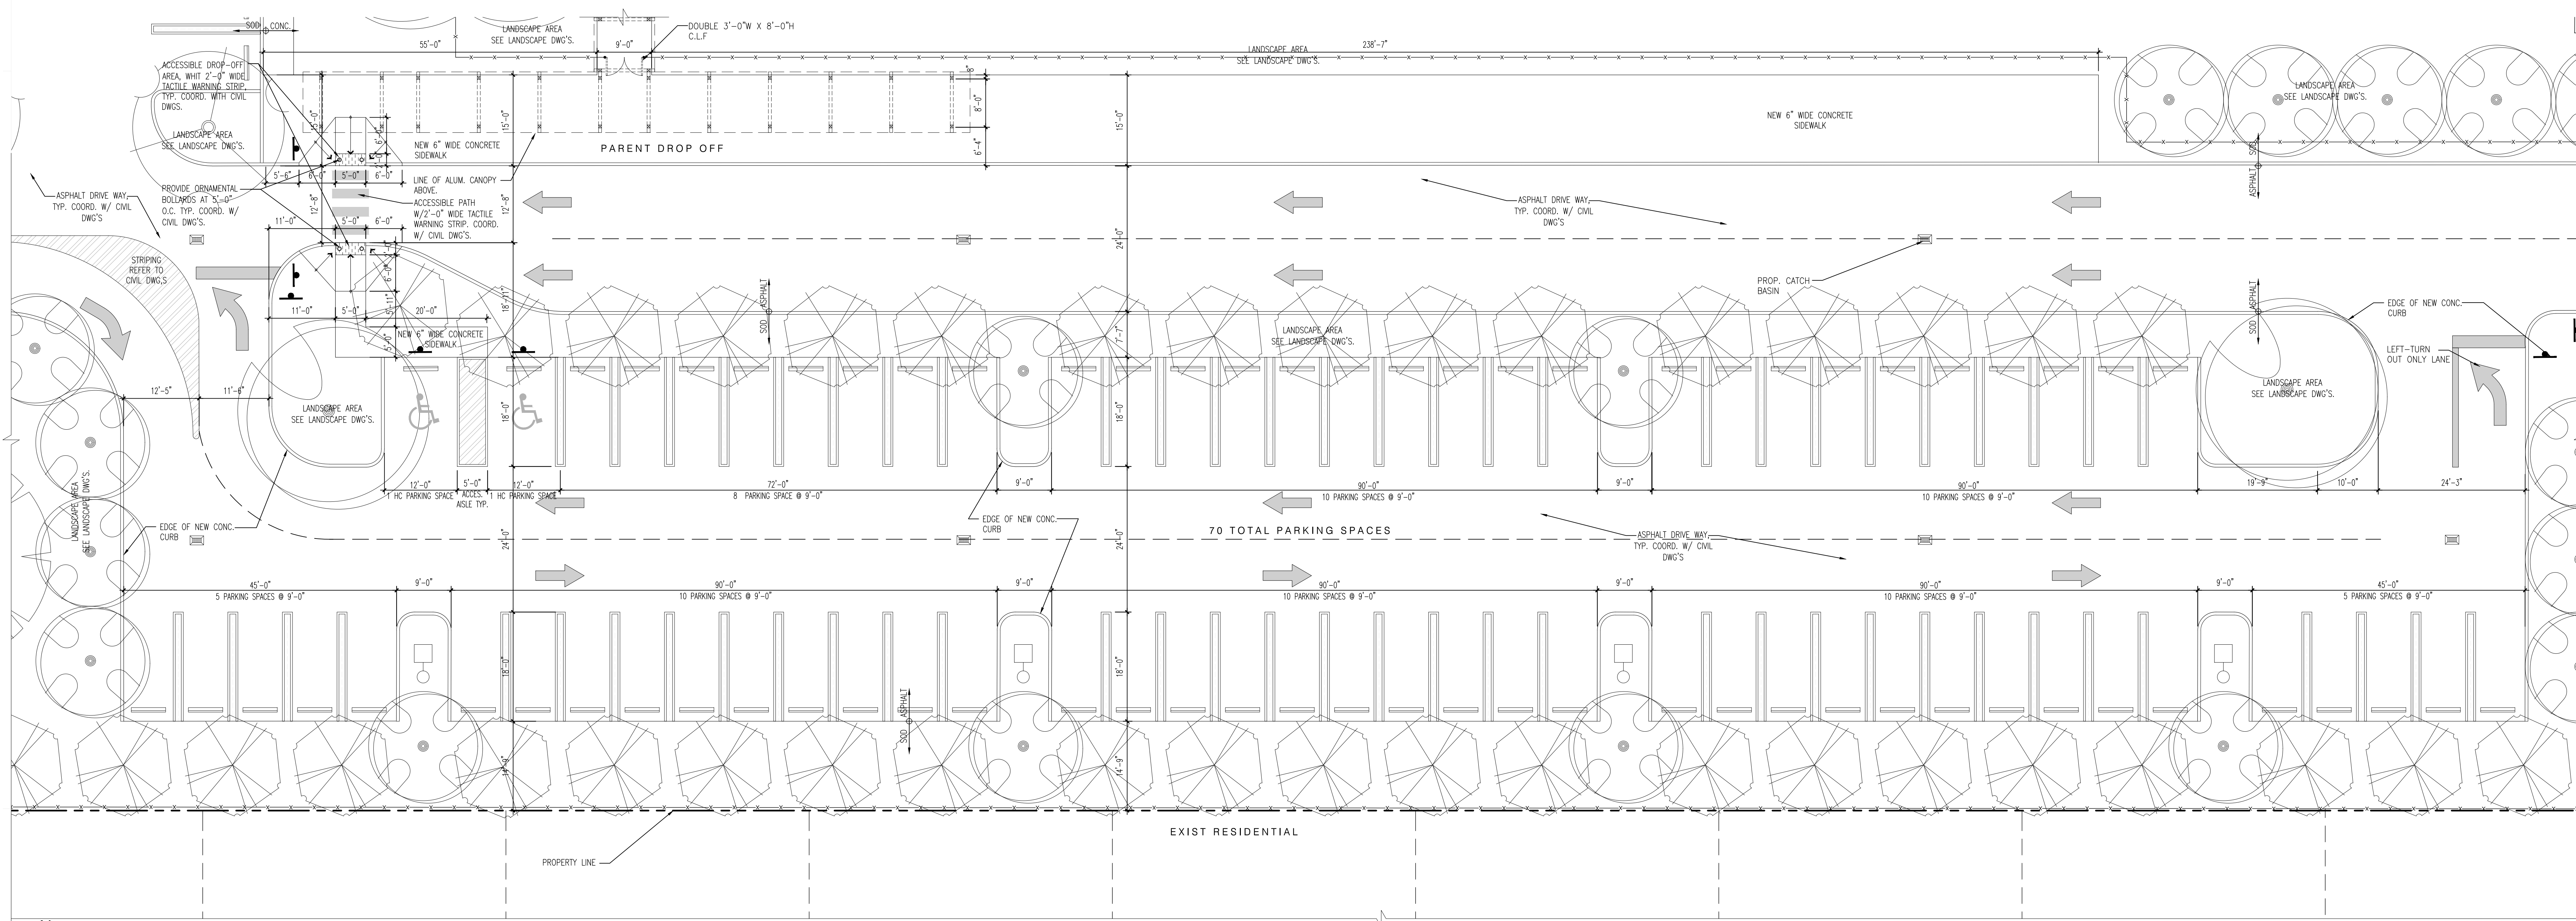


1
A-103
ENLARGED SITE PLAN - APRKING/ PARENT DROP OFF
Scale: 3/32"=1'-0"


<p>CHECKED BY: LR.</p> <p>DRAWN BY: CV.</p>	<p>CONSULTANT INFO:</p>	<p>MIAMI-DADE COUNTY PUBLIC SCHOOLS giving our students the world</p> <p>NEW ELEMENTARY SCHOOL (K-5) VENETIAN PARC WEST SOUTHWEST 157th AVENUE and 174th STREET MIAMI, FL. 33187 MDCPS PROJECT No. 01892600</p>	<p>KEY PLAN</p>	<p>CONSULTANT INFO:</p> <p>RODRIGUEZ ARCHITECTS INCORPORATED 2121 PONCE DE LEON BLVD. STE. 1010 CORAL GABLES, FL. 33134 TEL: (305) 448-3373 FAX: (305) 448-3374 A A C - 0 0 1 9 3 3</p>	<p>REVISIONS:</p> <p>RAI</p>	<p>DRAWING TITLE: ENLARGED SITE PLAN ENTRY PLAZA SCALE AS NOTED ISSUE DATE: 12/16/14 PROJECT NO: 1906 SHEET: A-103</p>
---	-------------------------	--	-----------------	---	------------------------------	--

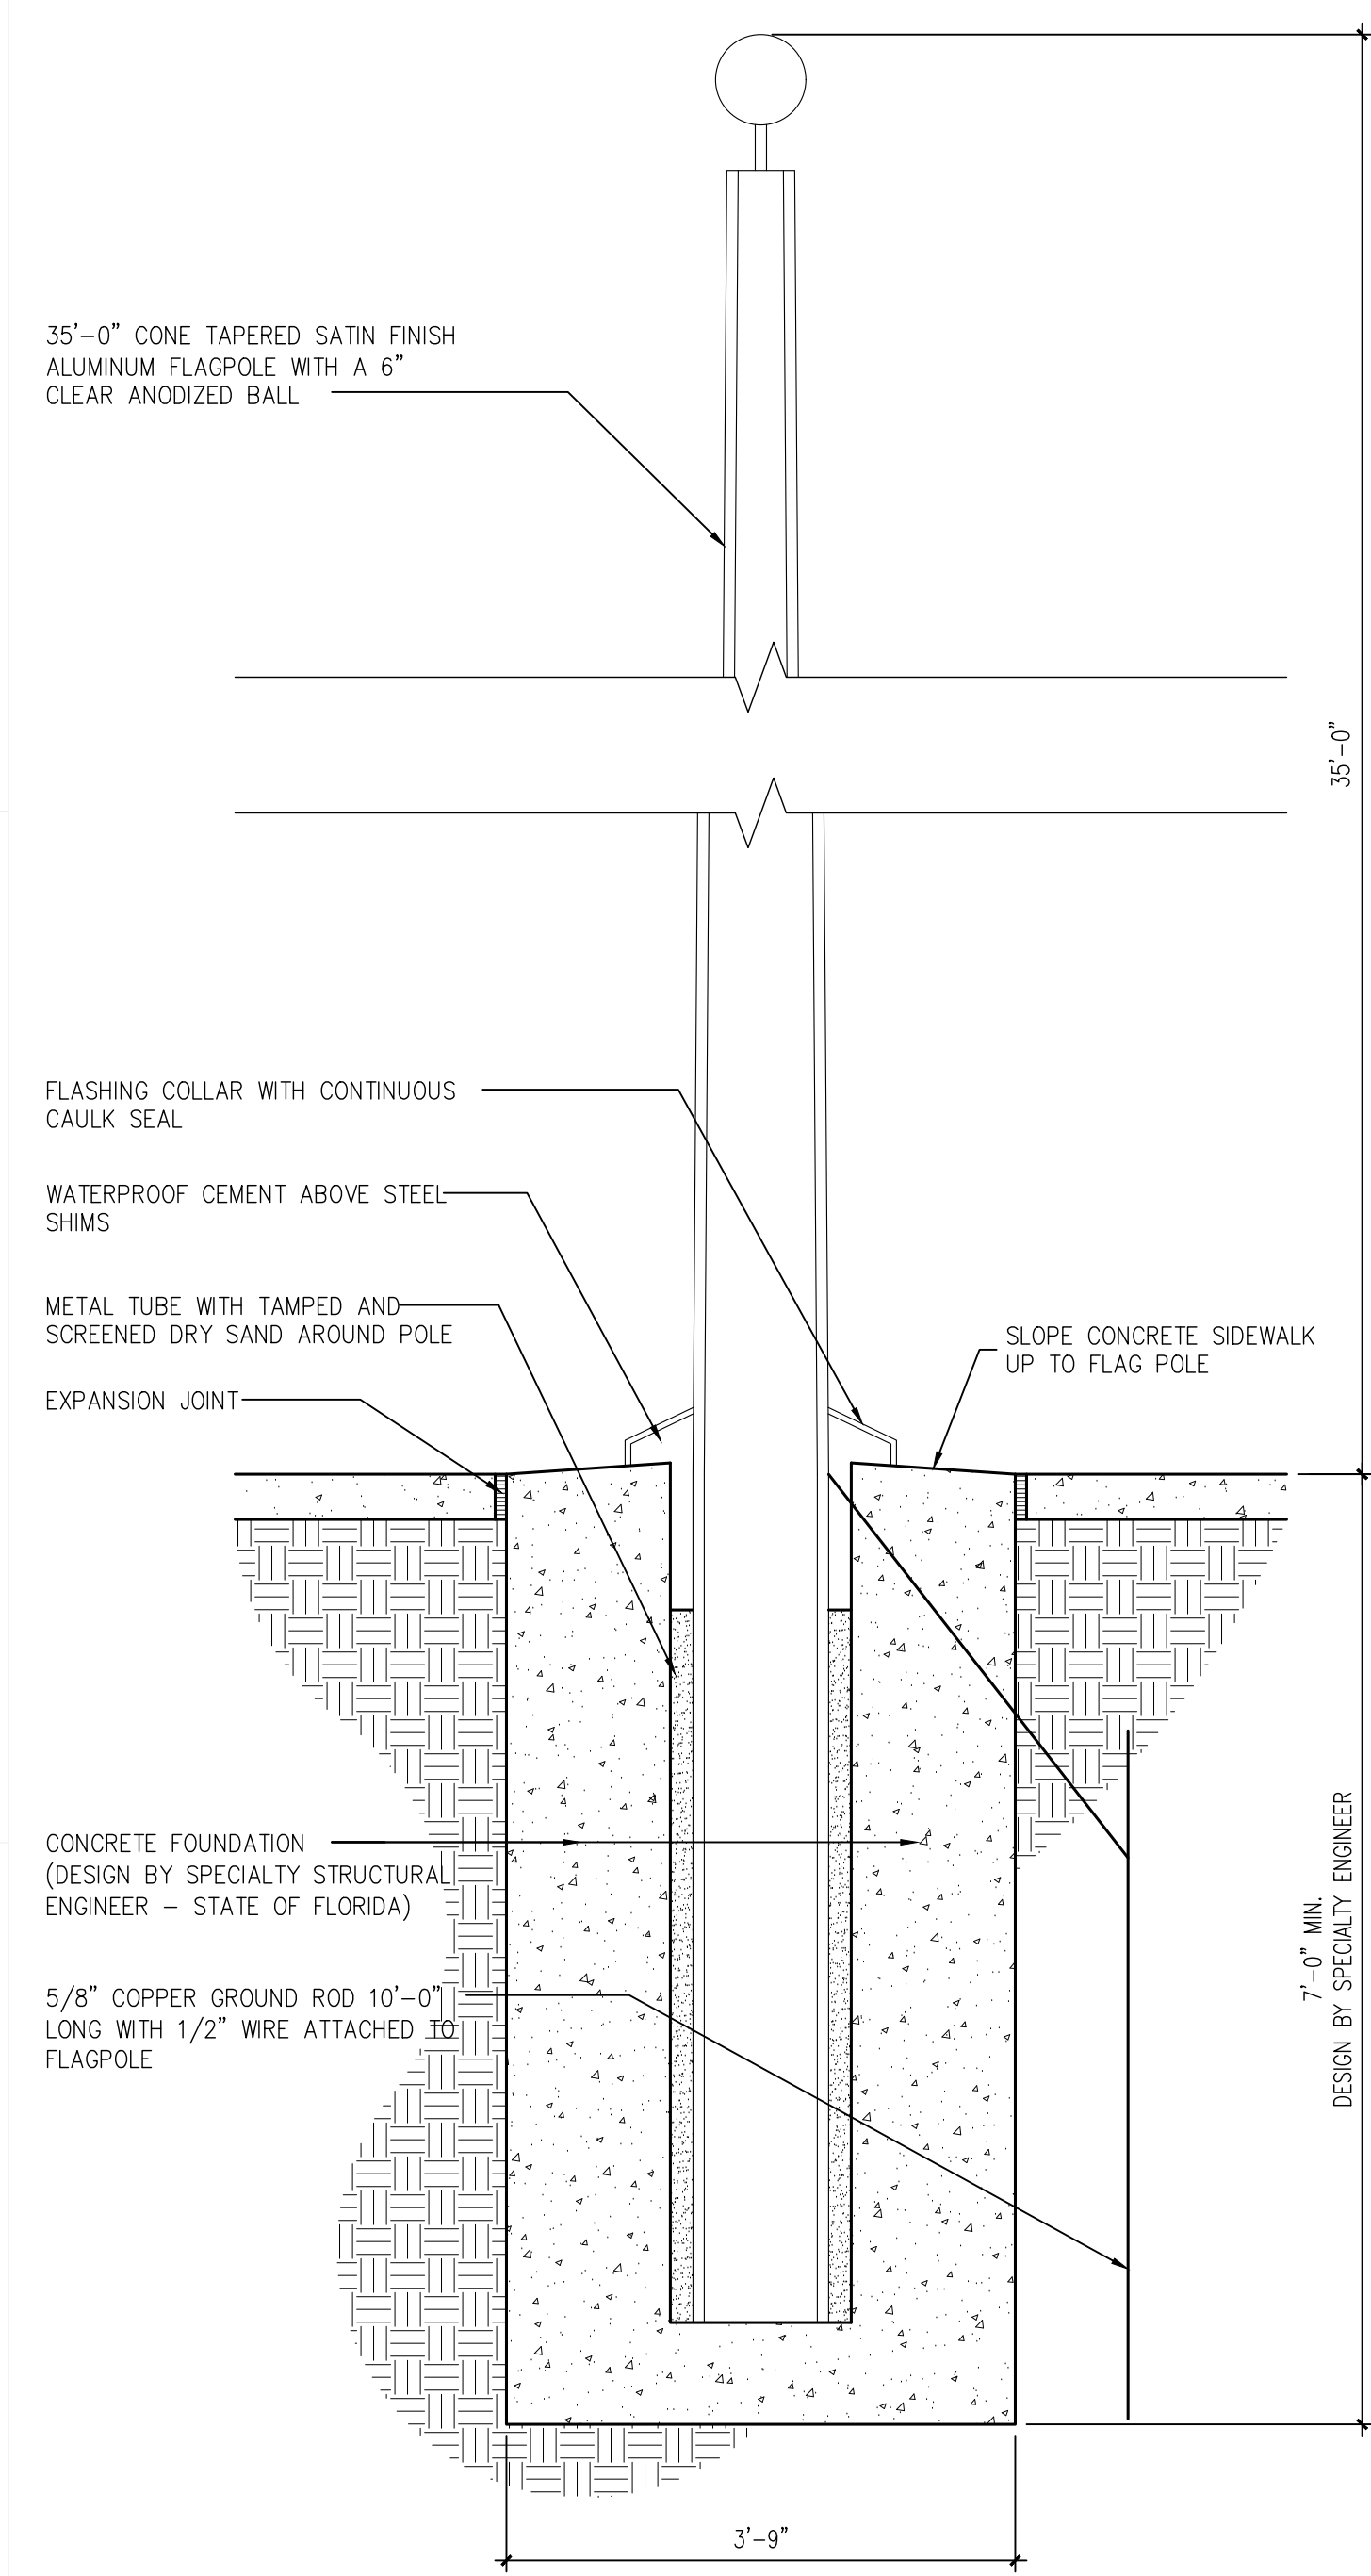


10 SITE FLAG POLE DETAIL
A-110 Scale: 3/4" = 1'-0"

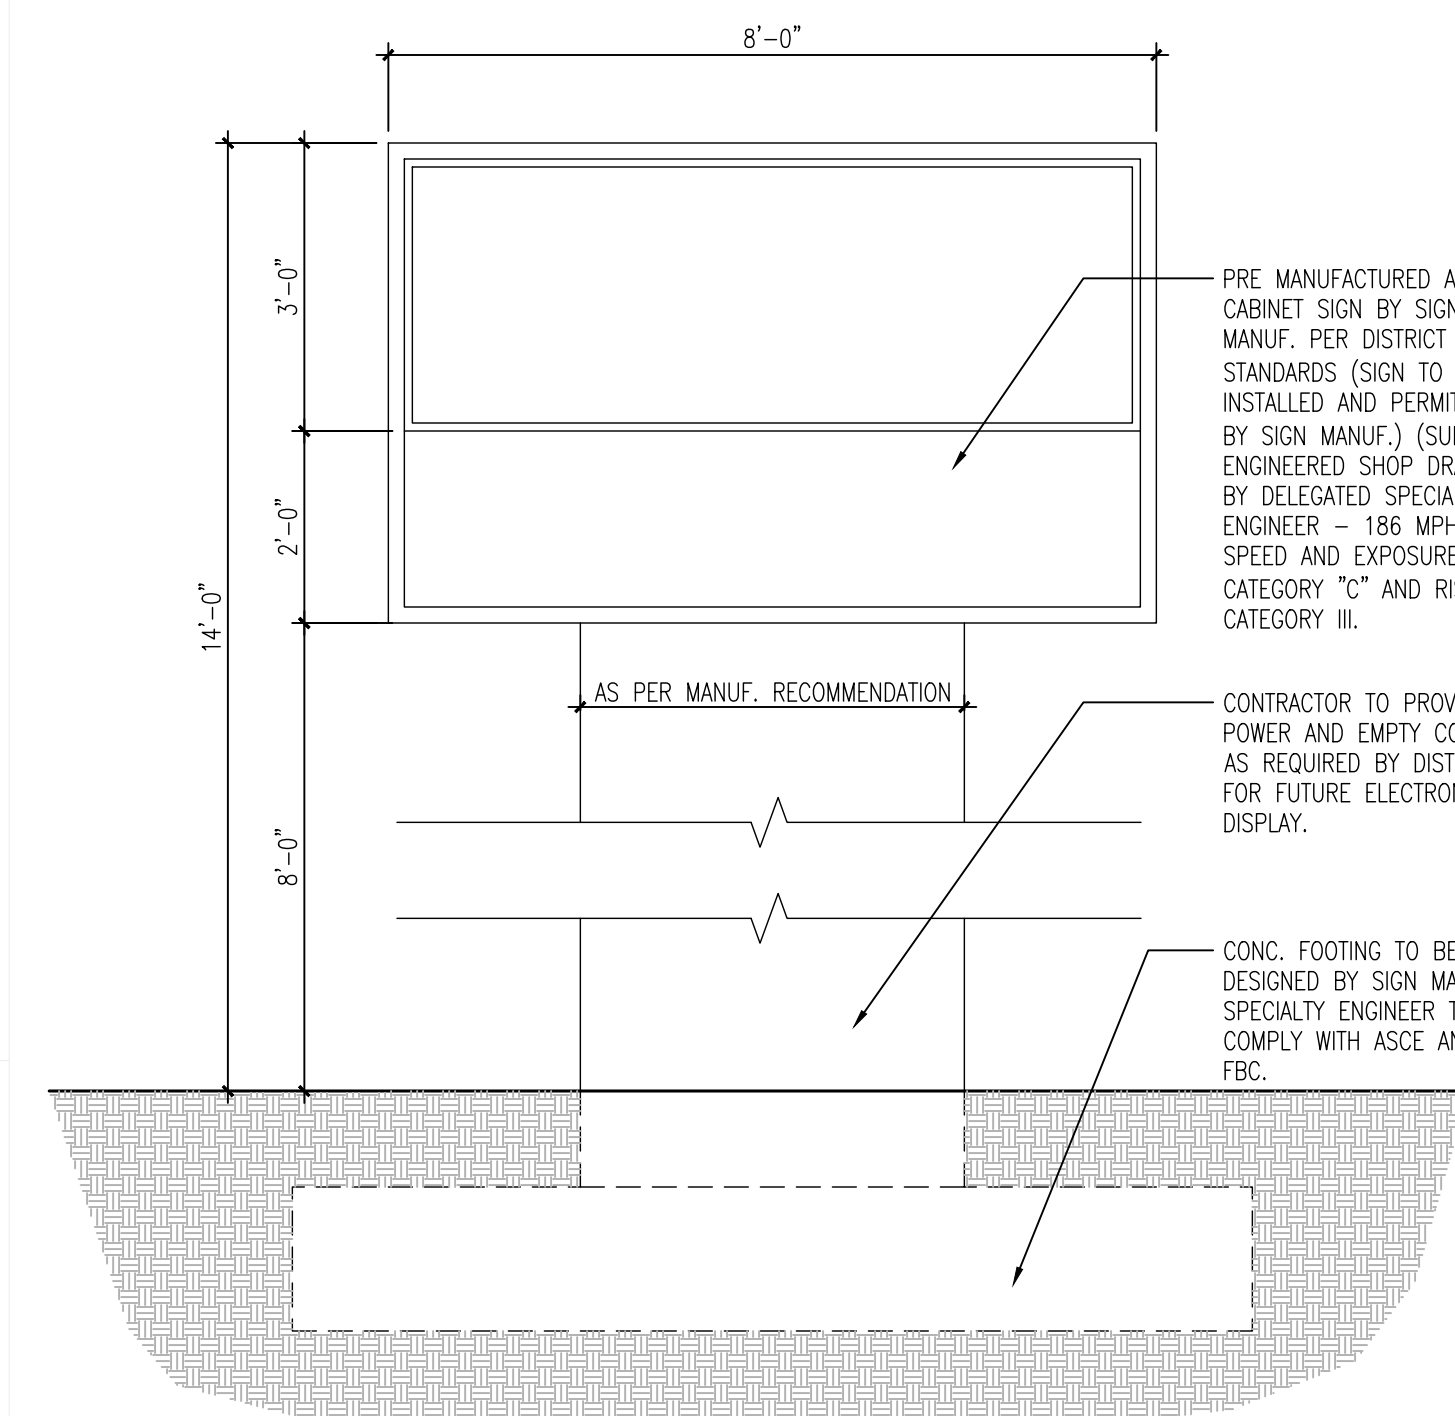


5 MARQUEE SIGN DETAIL
A-110 Scale: 1/2" = 1'-0"

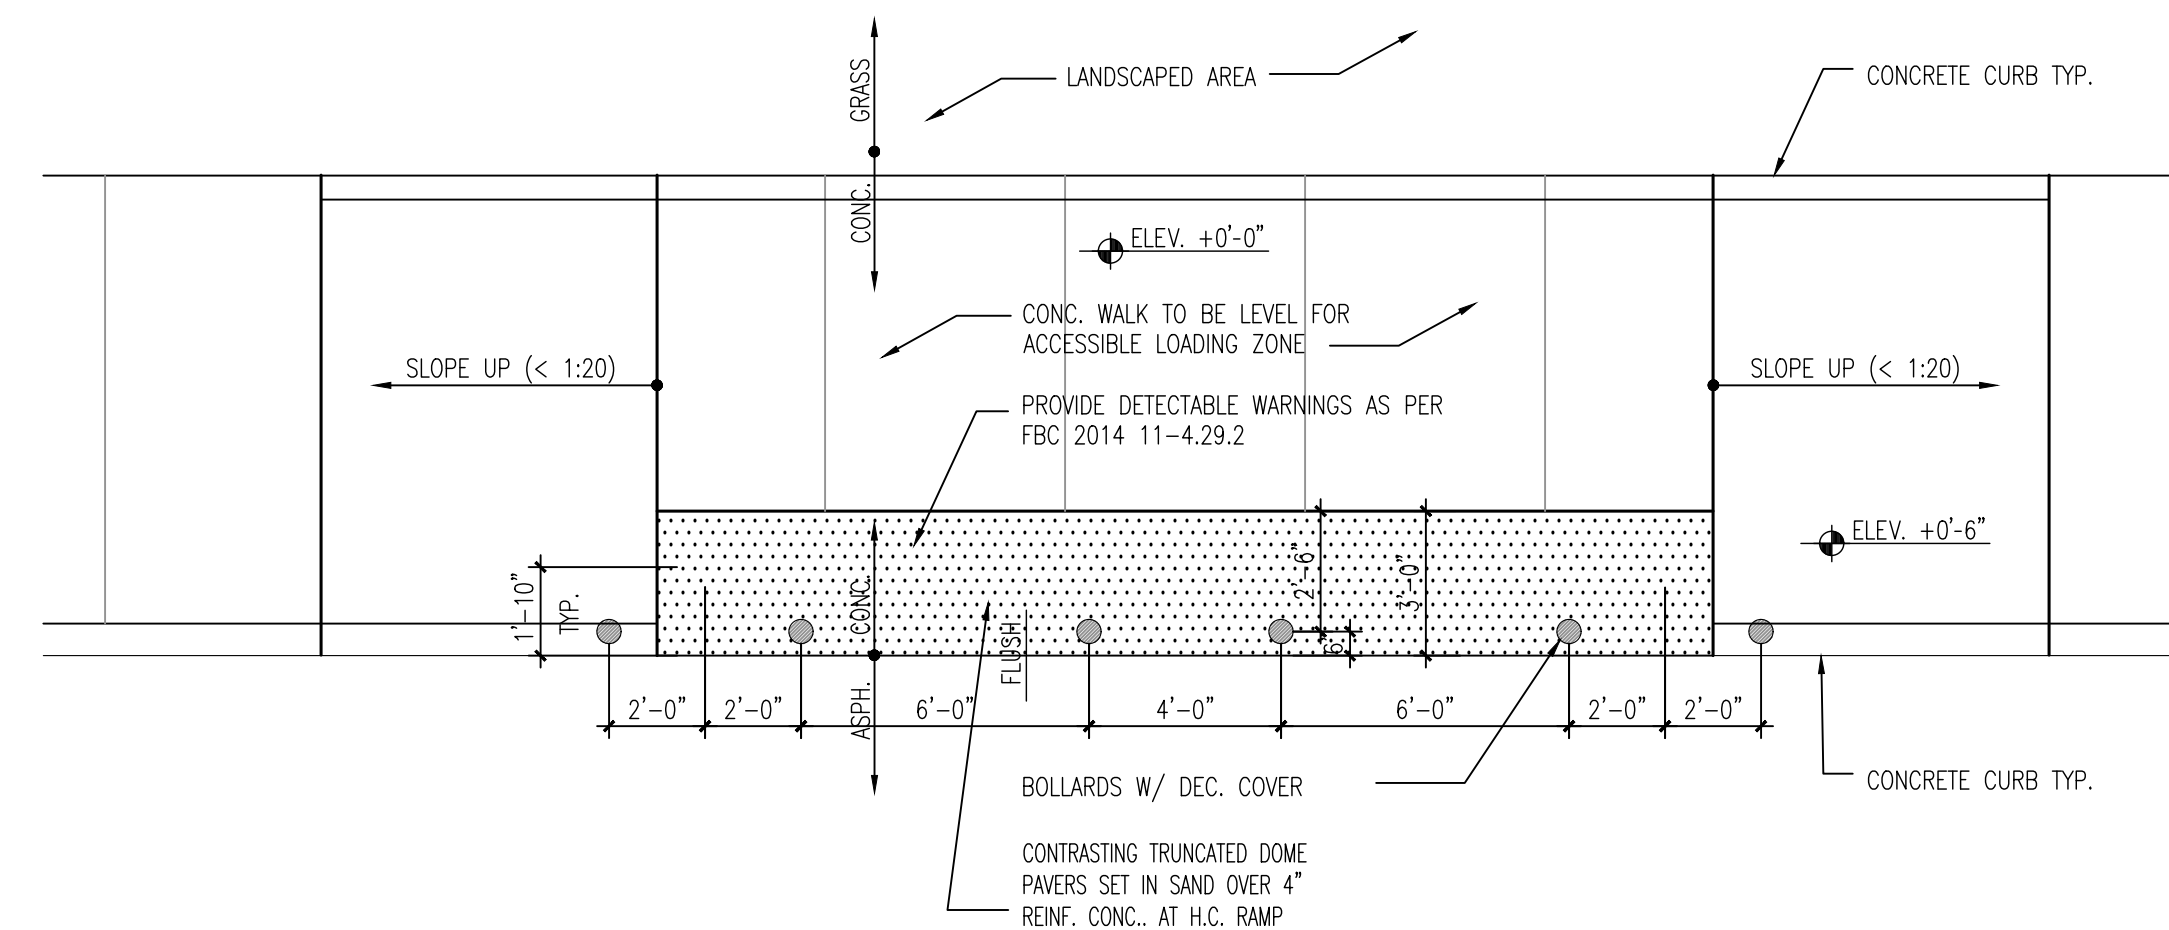


13 ADA PASSENGER LOADING ACCESS AISLE
A-110 Scale: 1/4" = 1'-0"

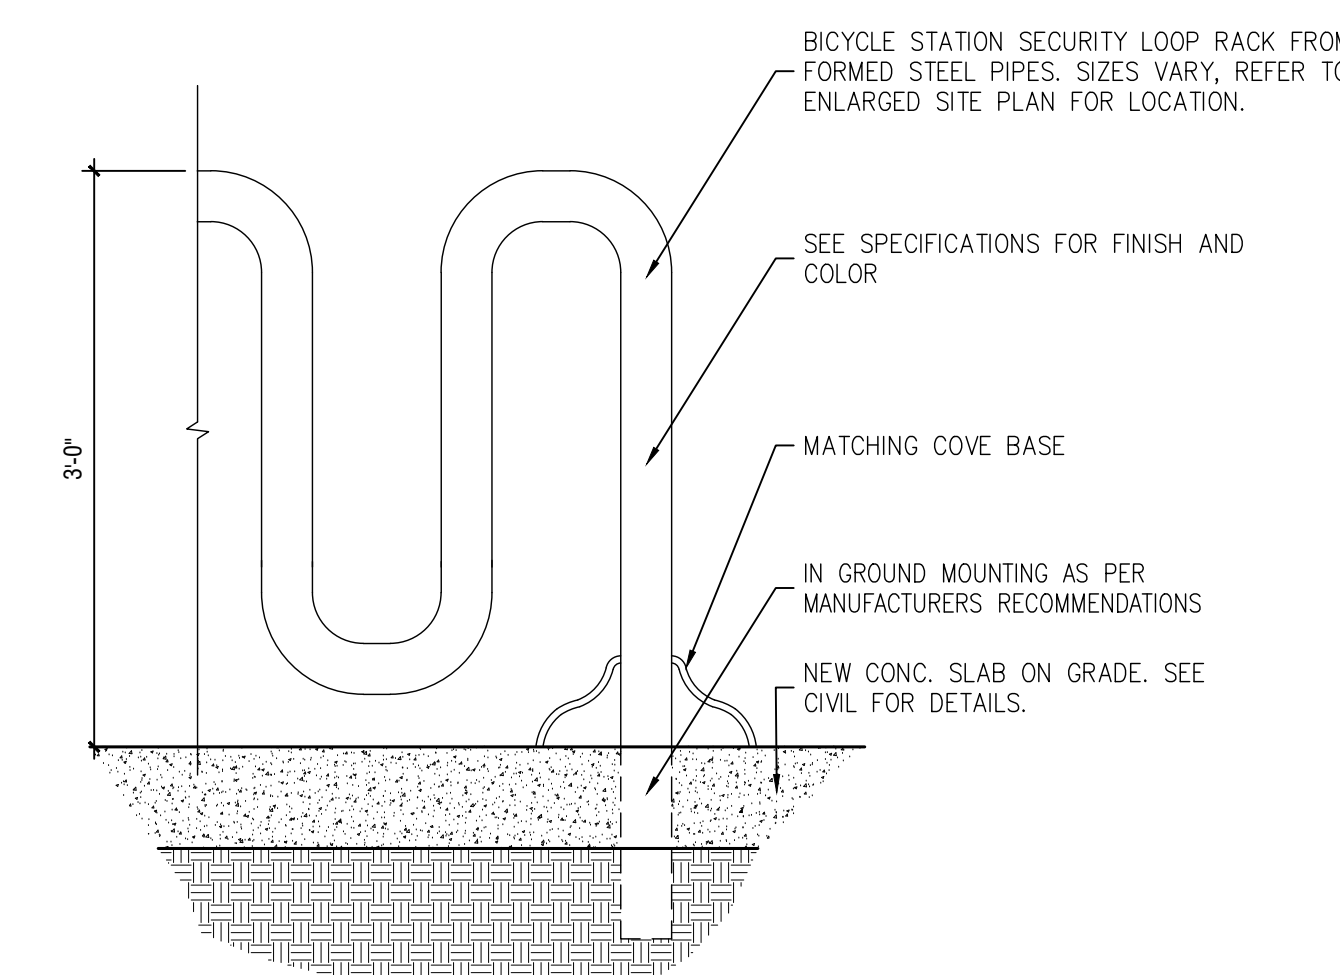


9 SITE BIKE RACK DETAIL
A-110 Scale: 1" = 1'-0"

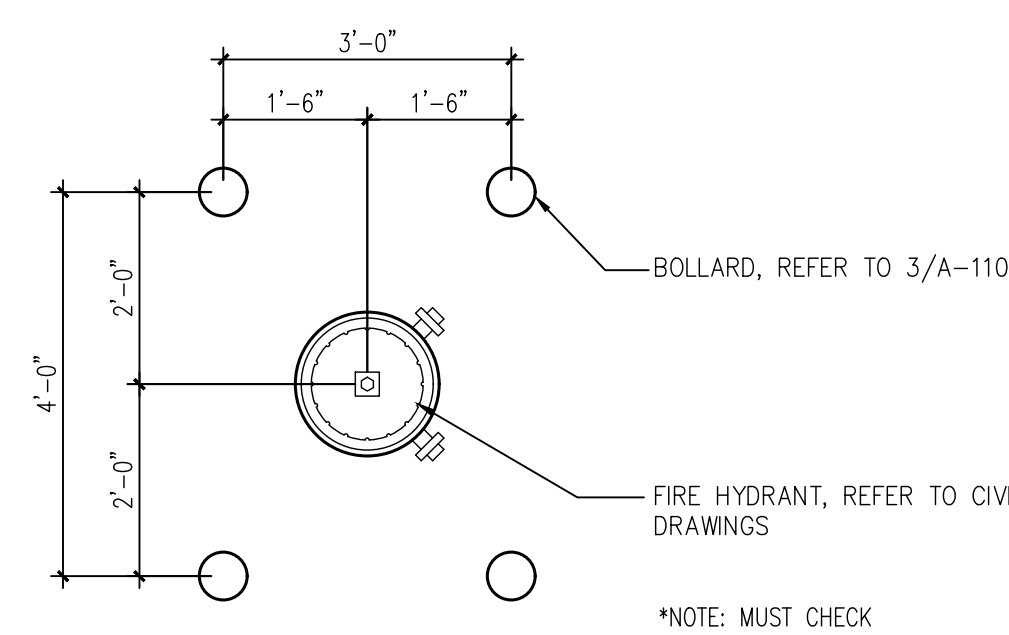


8 FIRE HYDRANT DETAIL
A-110 Scale: 1/2" = 1'-0"

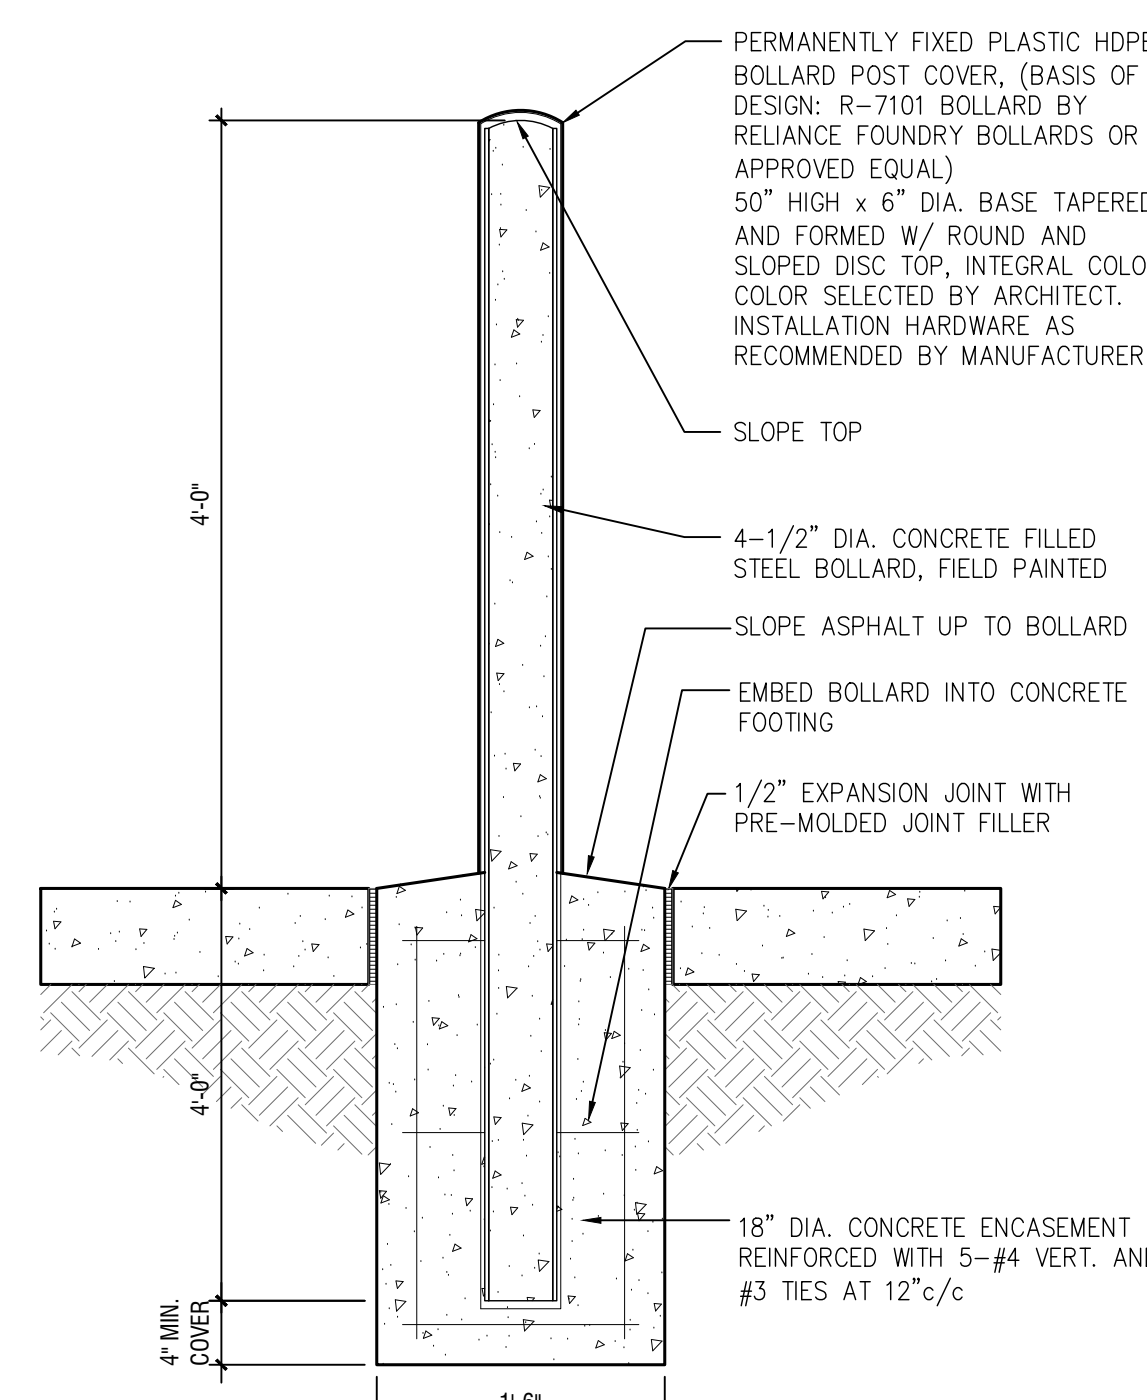


3 SITE BOLLARD/HYDRANT DETAIL
A-110 Scale: 1" = 1'-0"

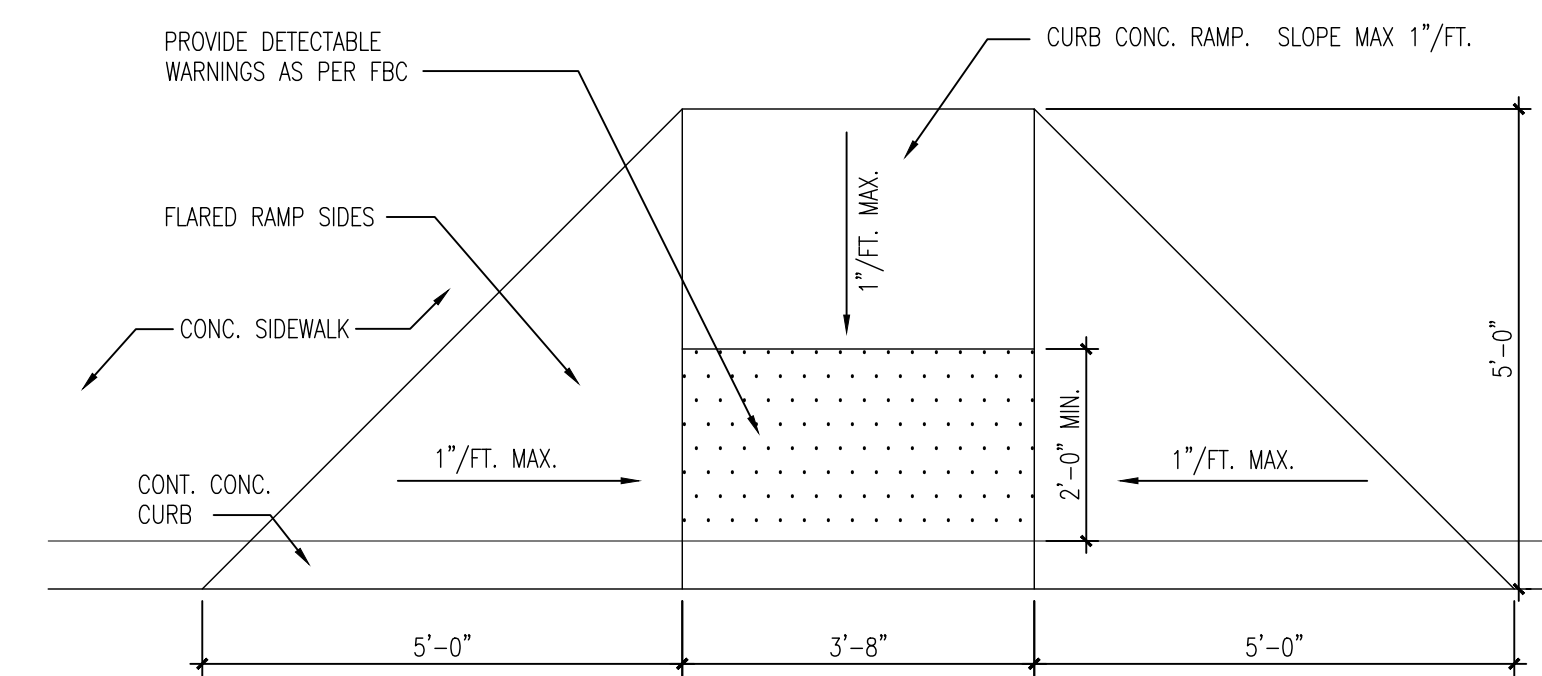


12 SITE PAVING DETAIL
A-110 Scale: 1/2" = 1'-0"

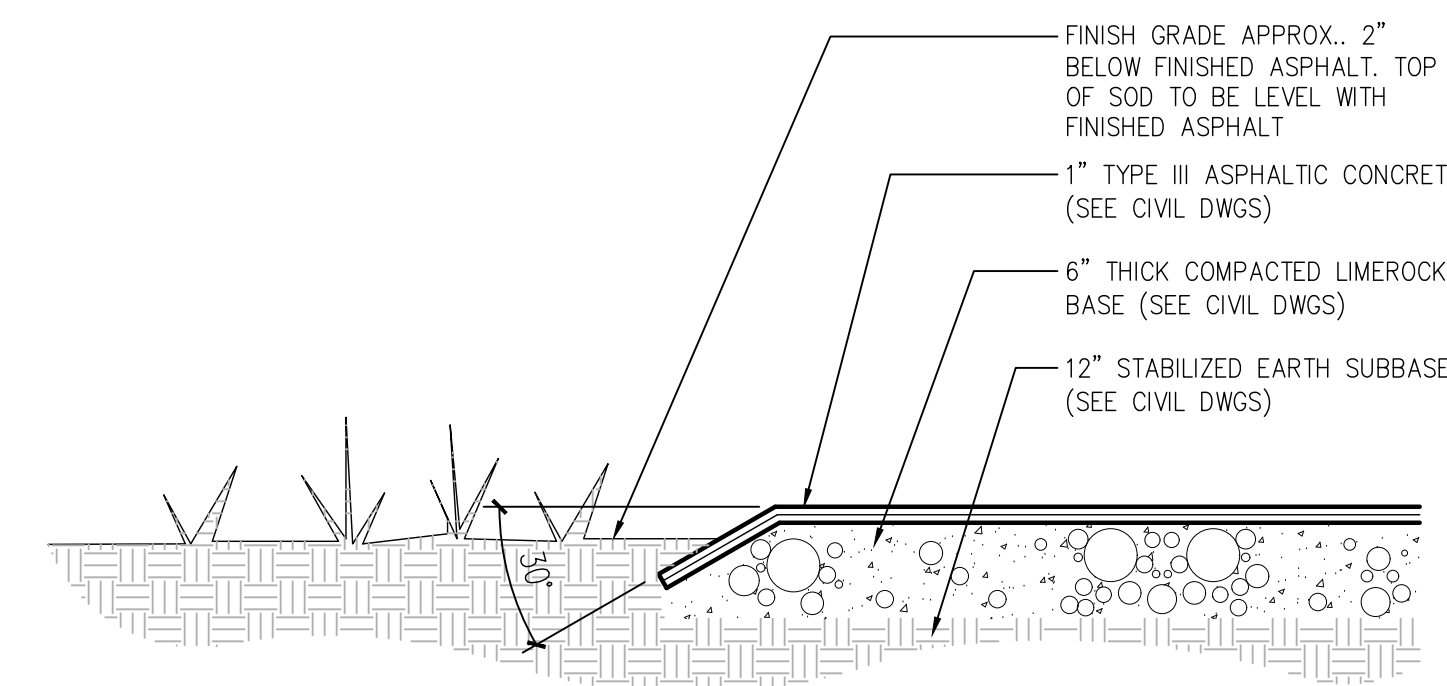


7 ASPHALT EDGE DETAIL
A-110 Scale: 1" = 1'-0"

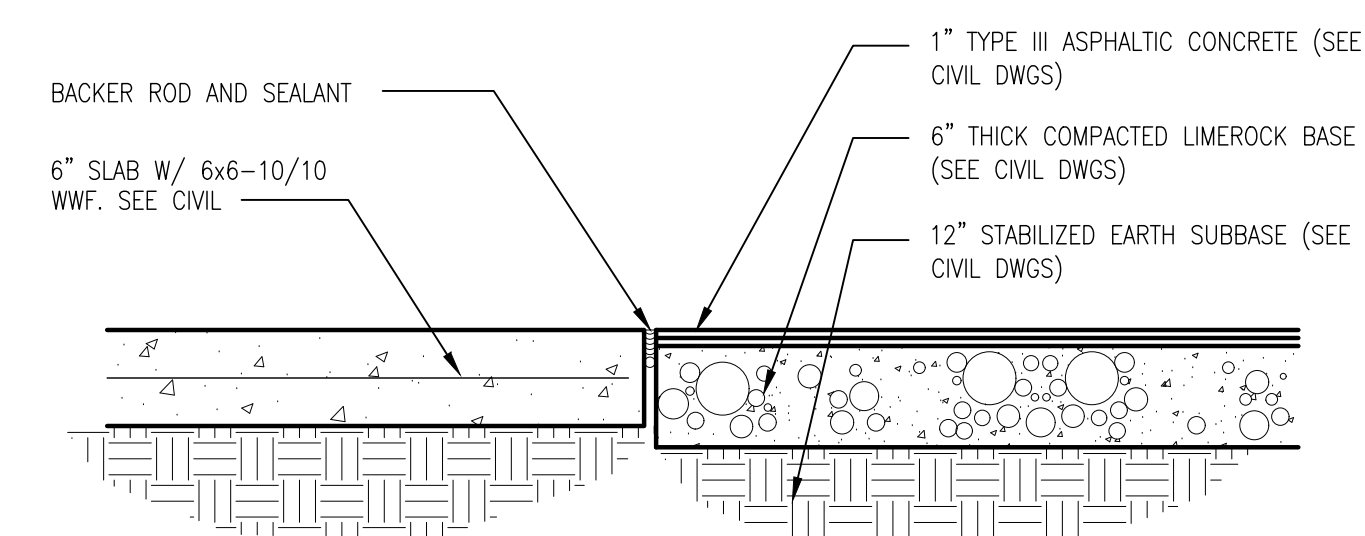


2 ASPHALT - CONCRETE WALK DETAIL
A-110 Scale: 1" = 1'-0"

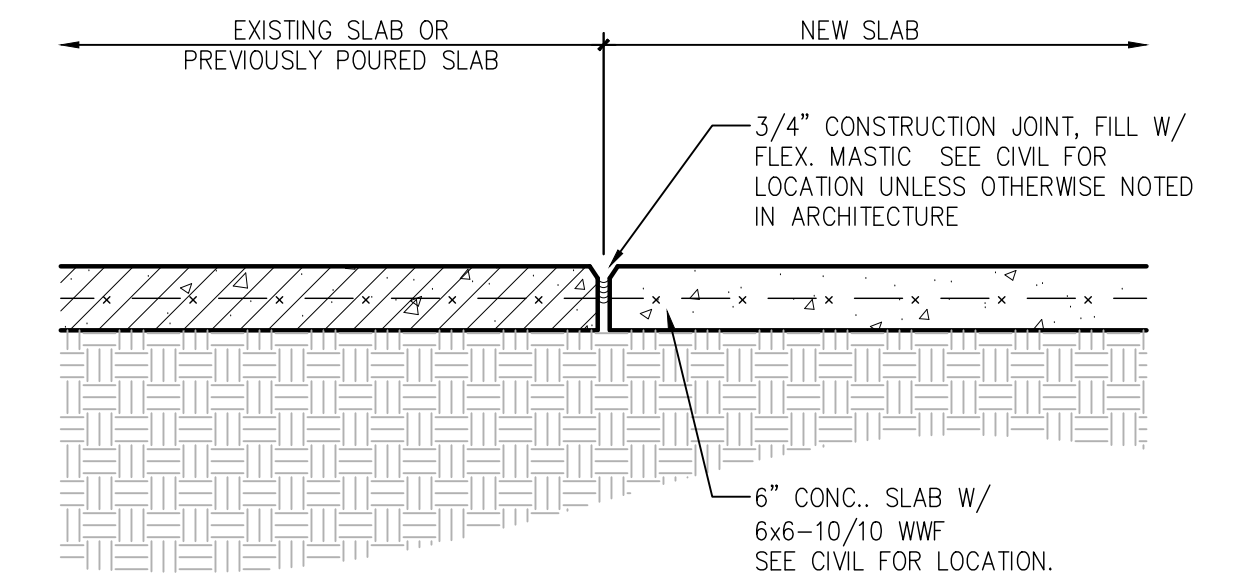


11 CONSTRUCTION JOINT DETAIL
A-110 Scale: 1" = 1'-0"

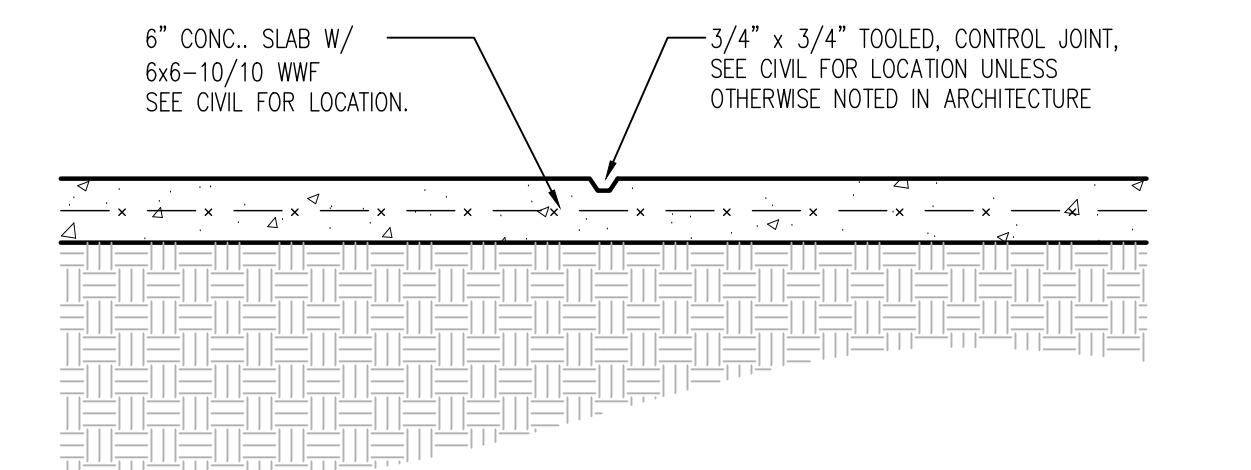


6 TOOLED JOINT DETAIL AT SIDEWALKS
A-110 Scale: 1" = 1'-0"

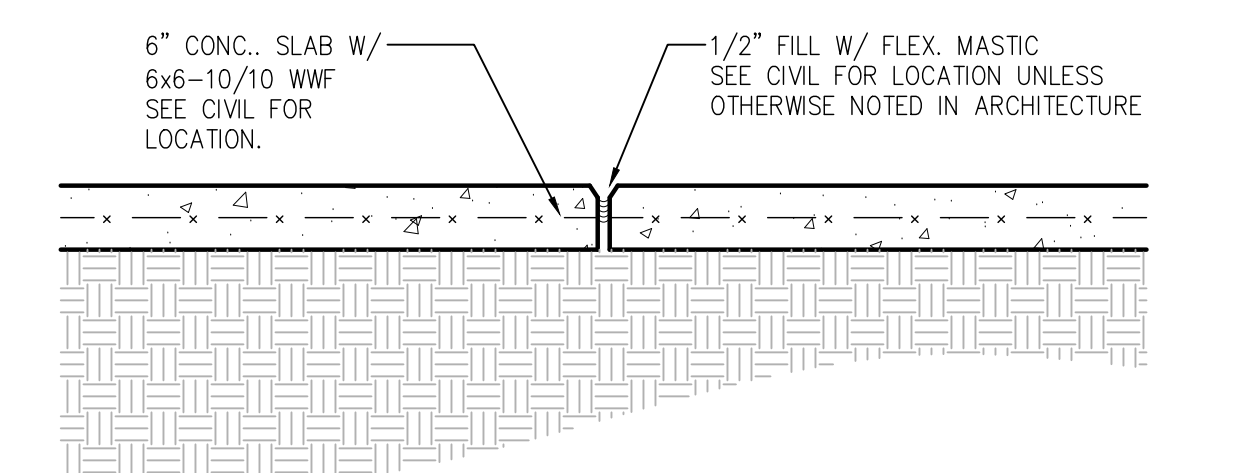


1 EXPANSION JOINT DETAIL
A-110 Scale: 1" = 1'-0"

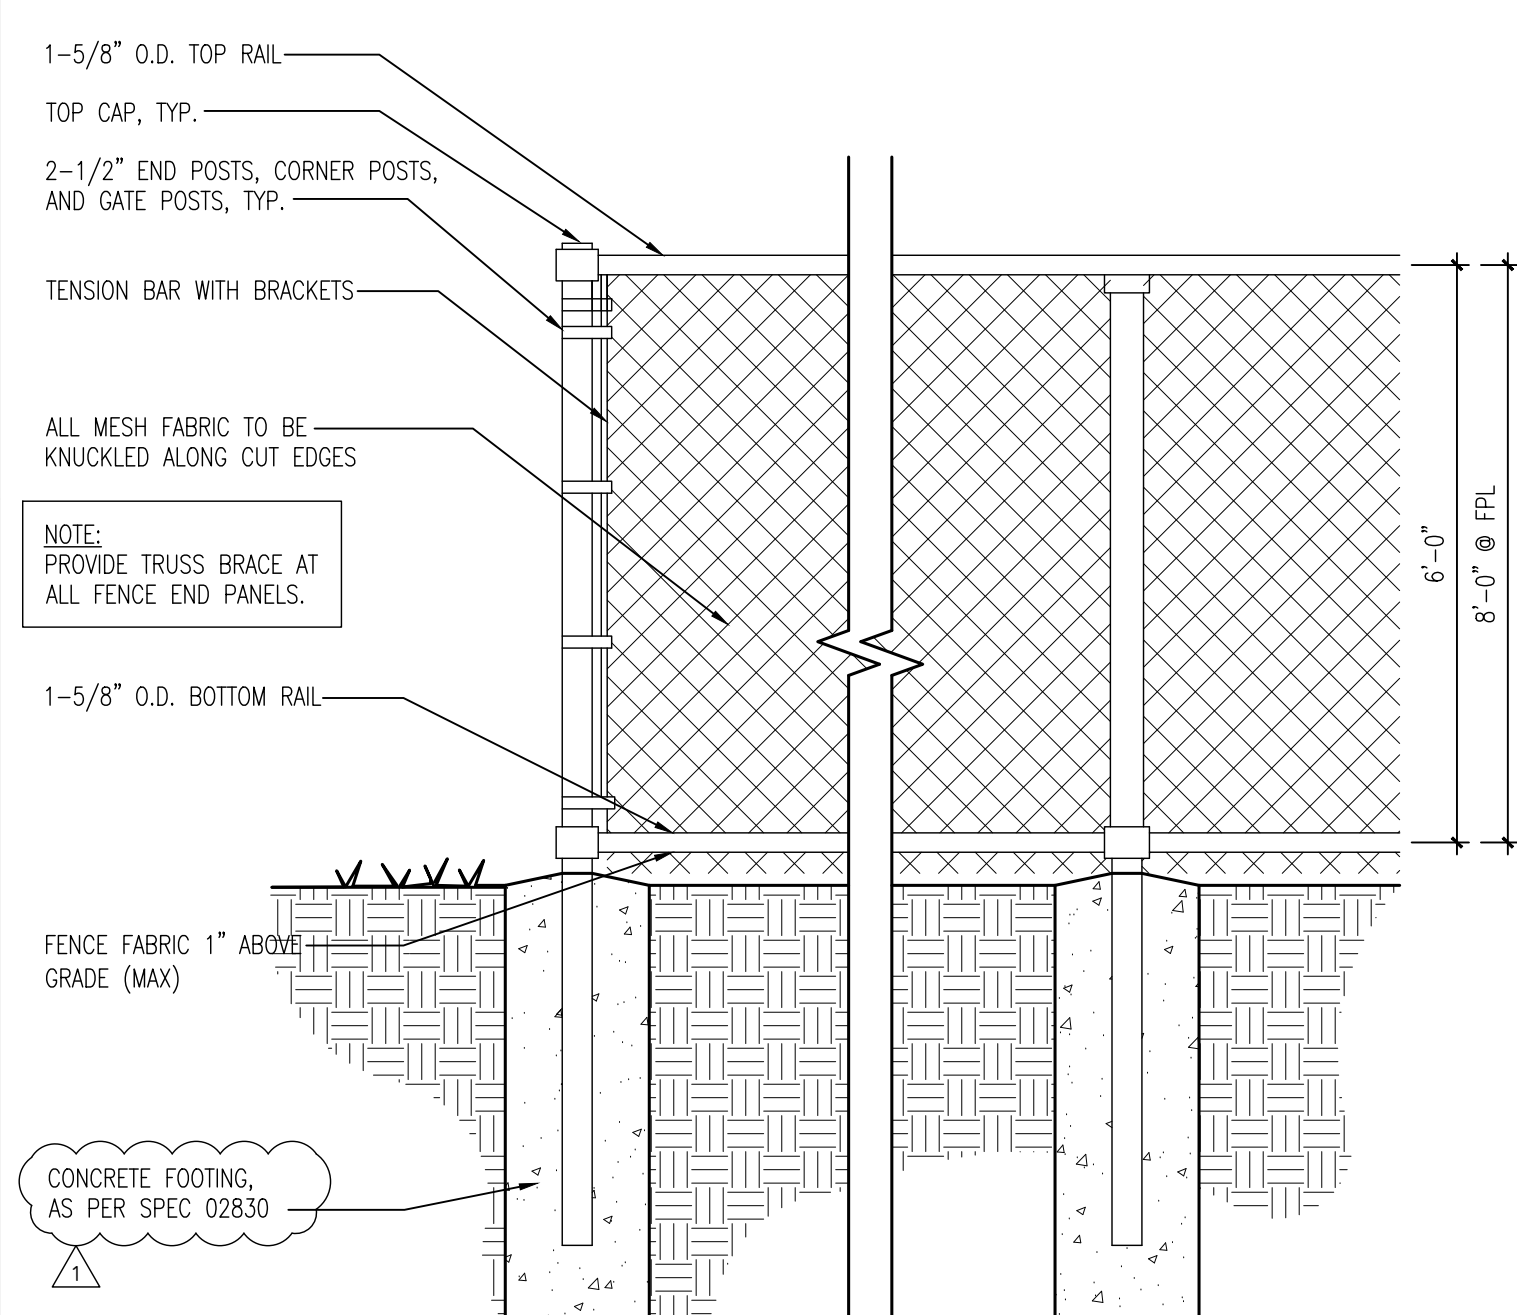


3 SITE FENCING DETAIL
A-111 Scale: 3/4" = 1'-0"

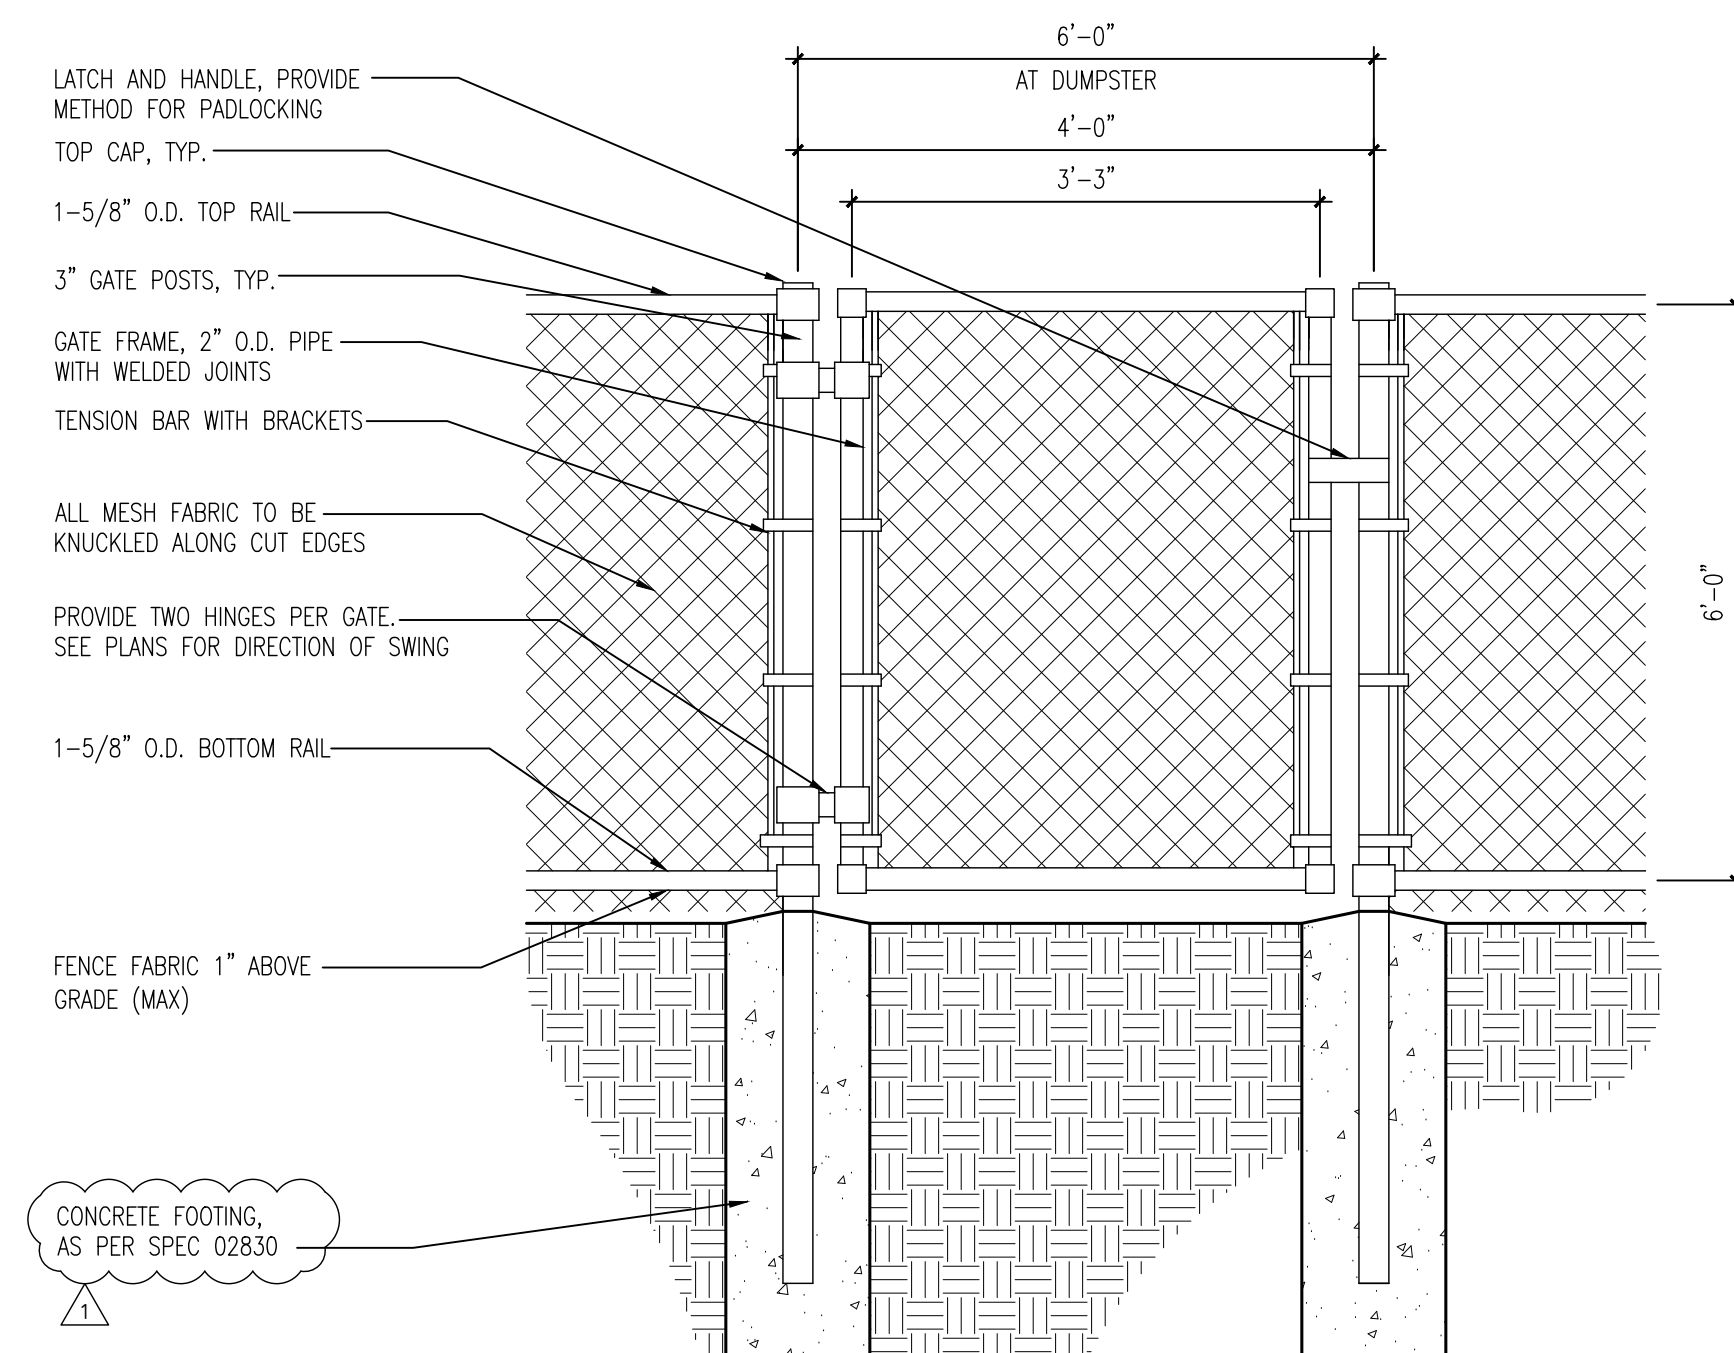


4 SITE FENCING DETAIL
A-111 Scale: 3/4" = 1'-0" (DETAIL (TYP.))

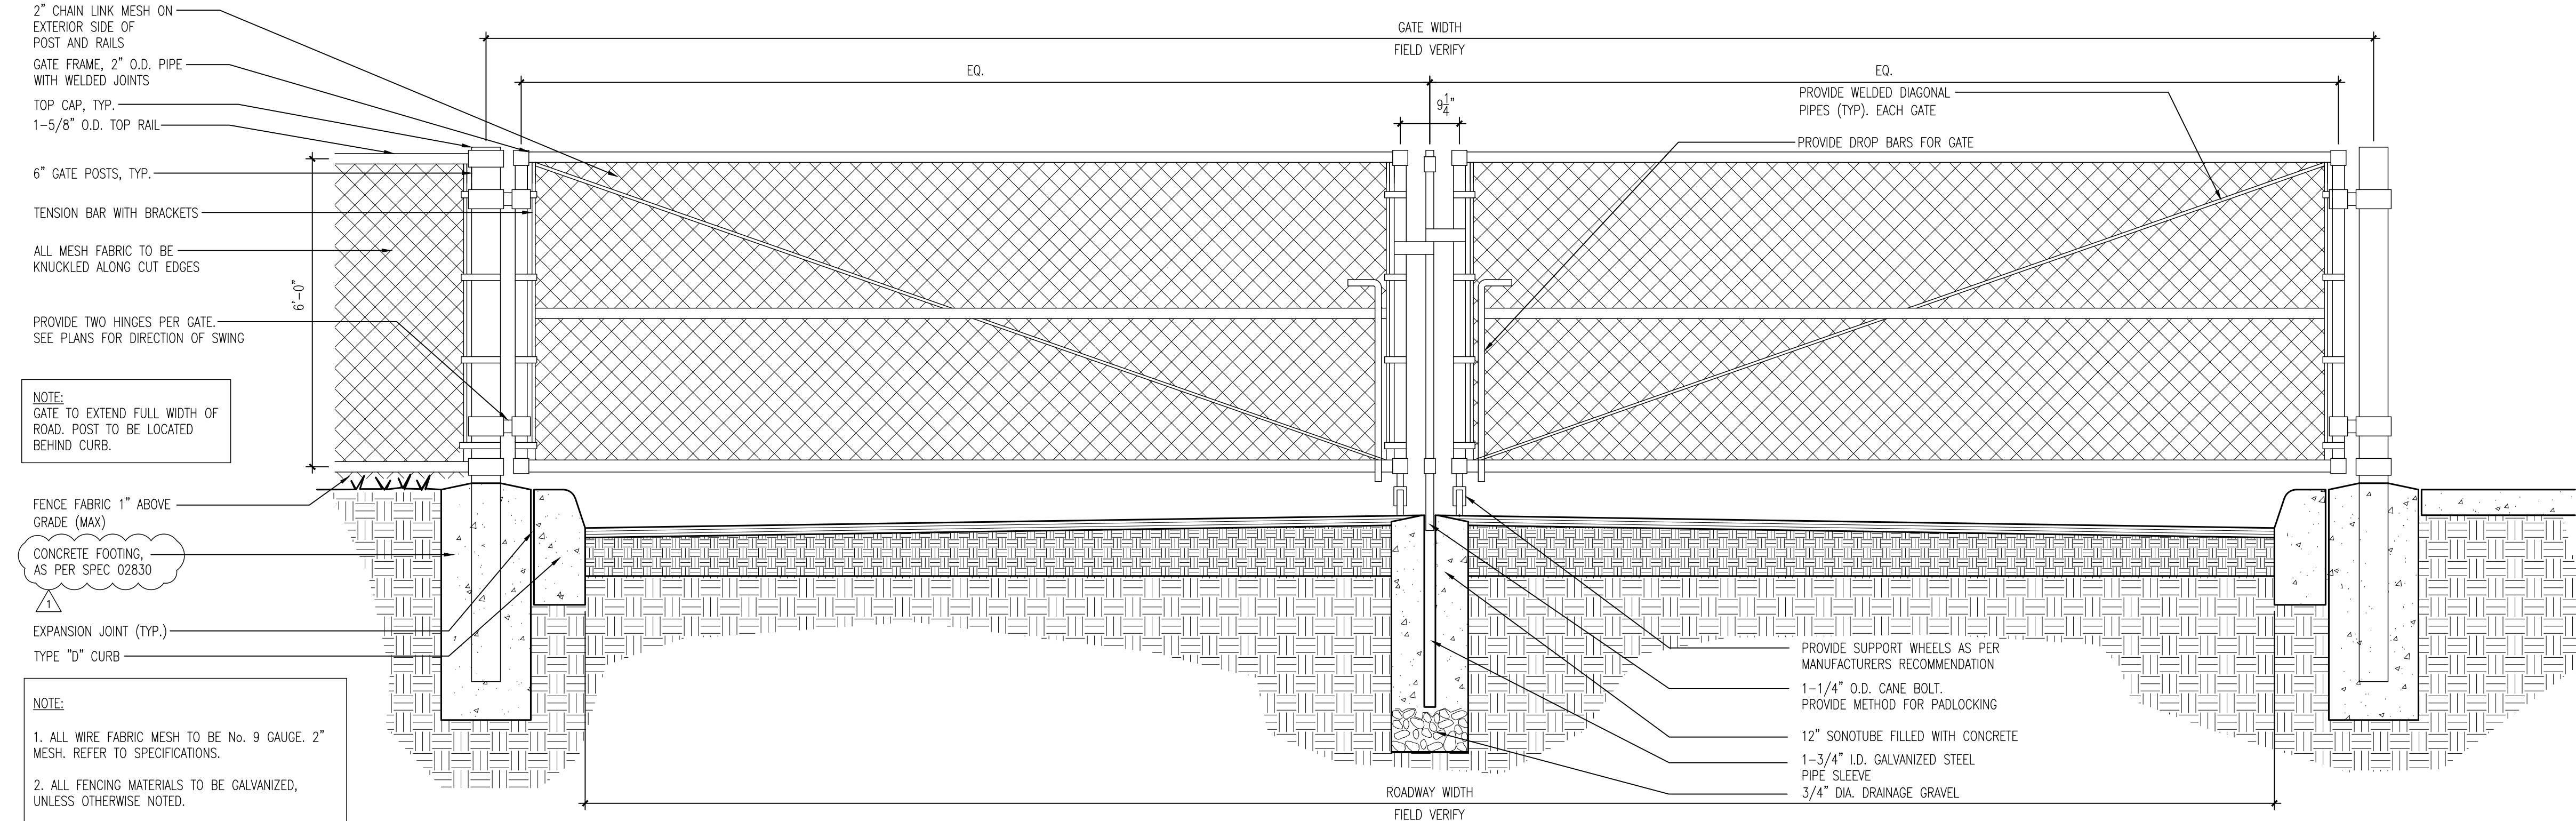


2 SITE FENCING DETAIL
A-111 Scale: 3/4" = 1'-0"

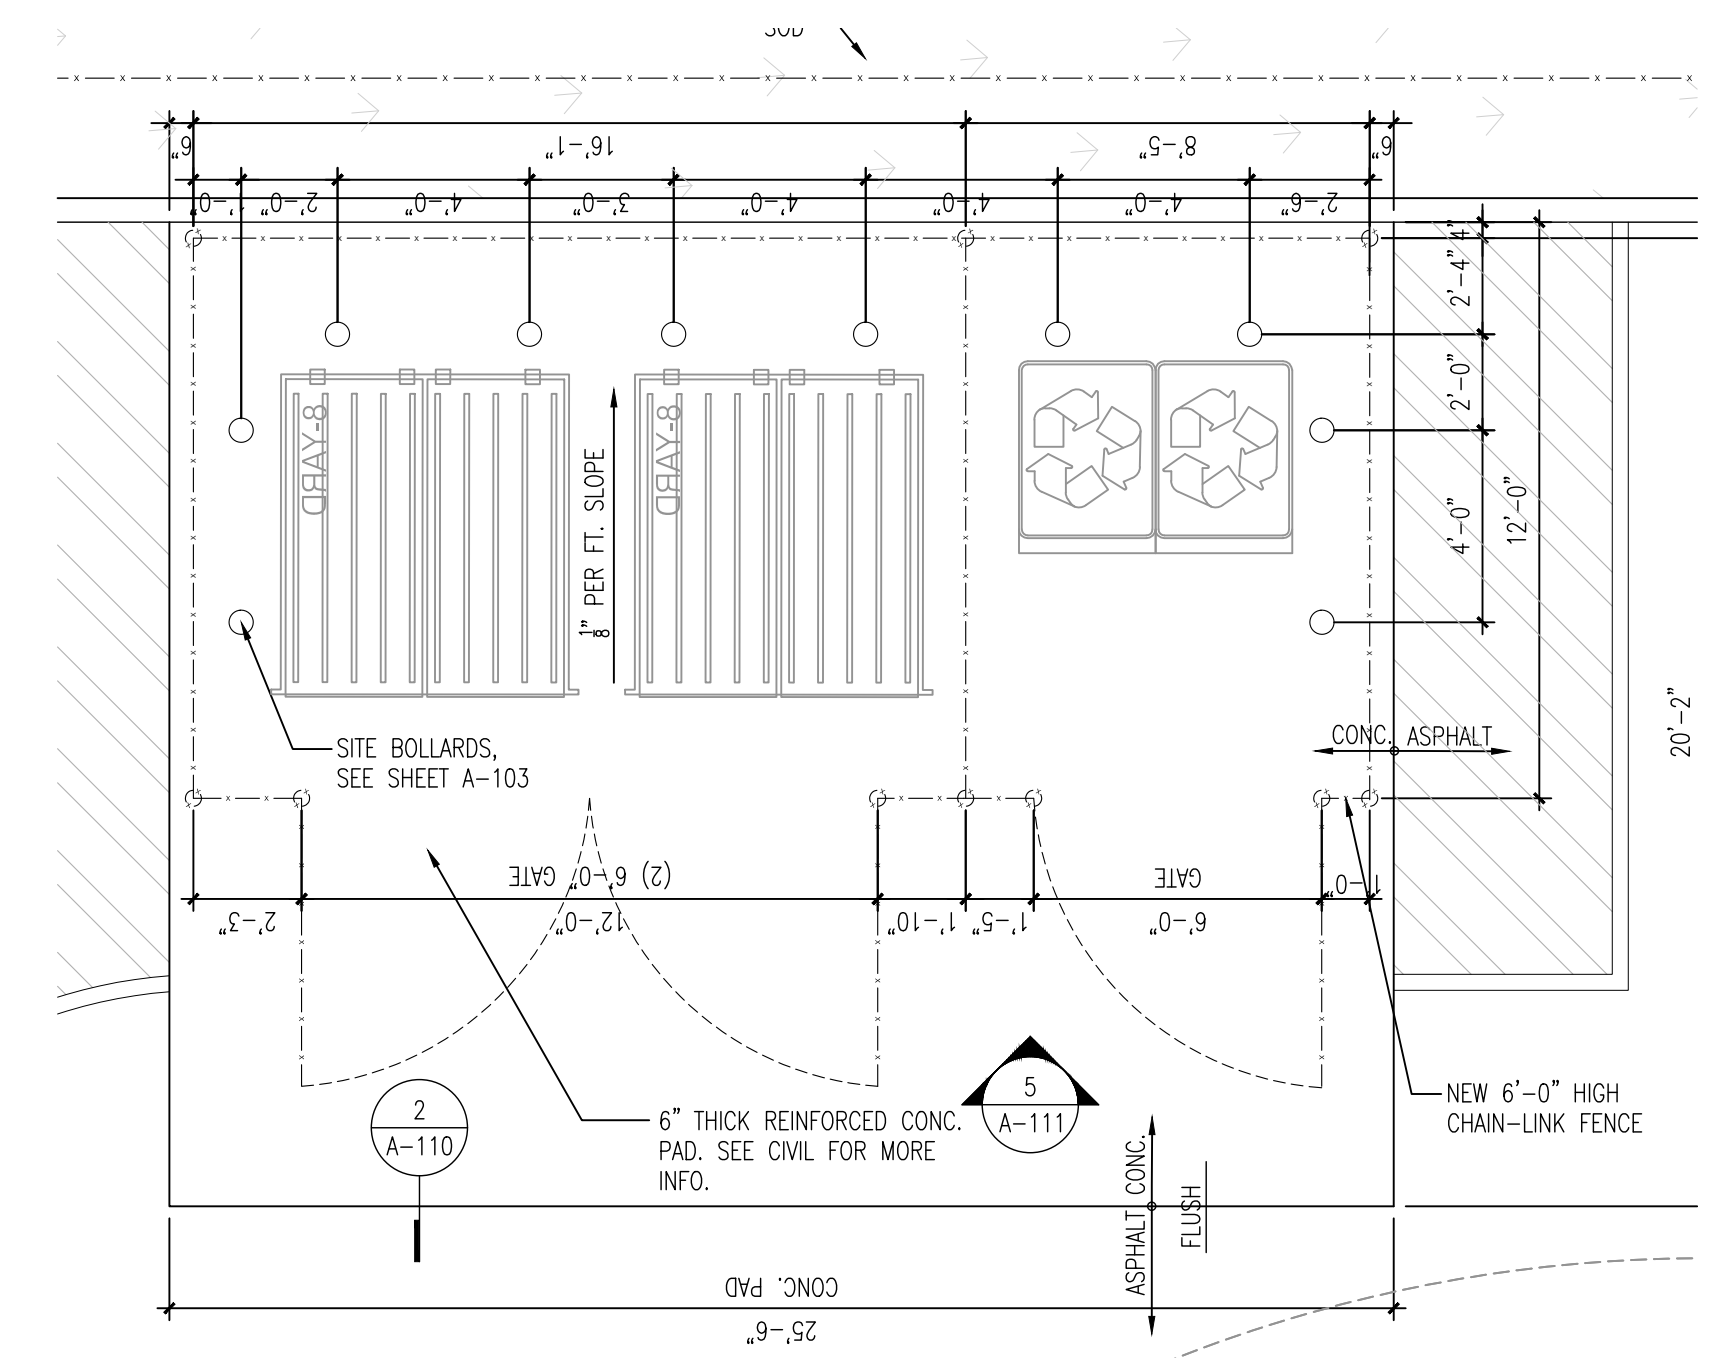

6 SITE PAVING DETAIL
A-111 Scale: 1/4" = 1'-0"

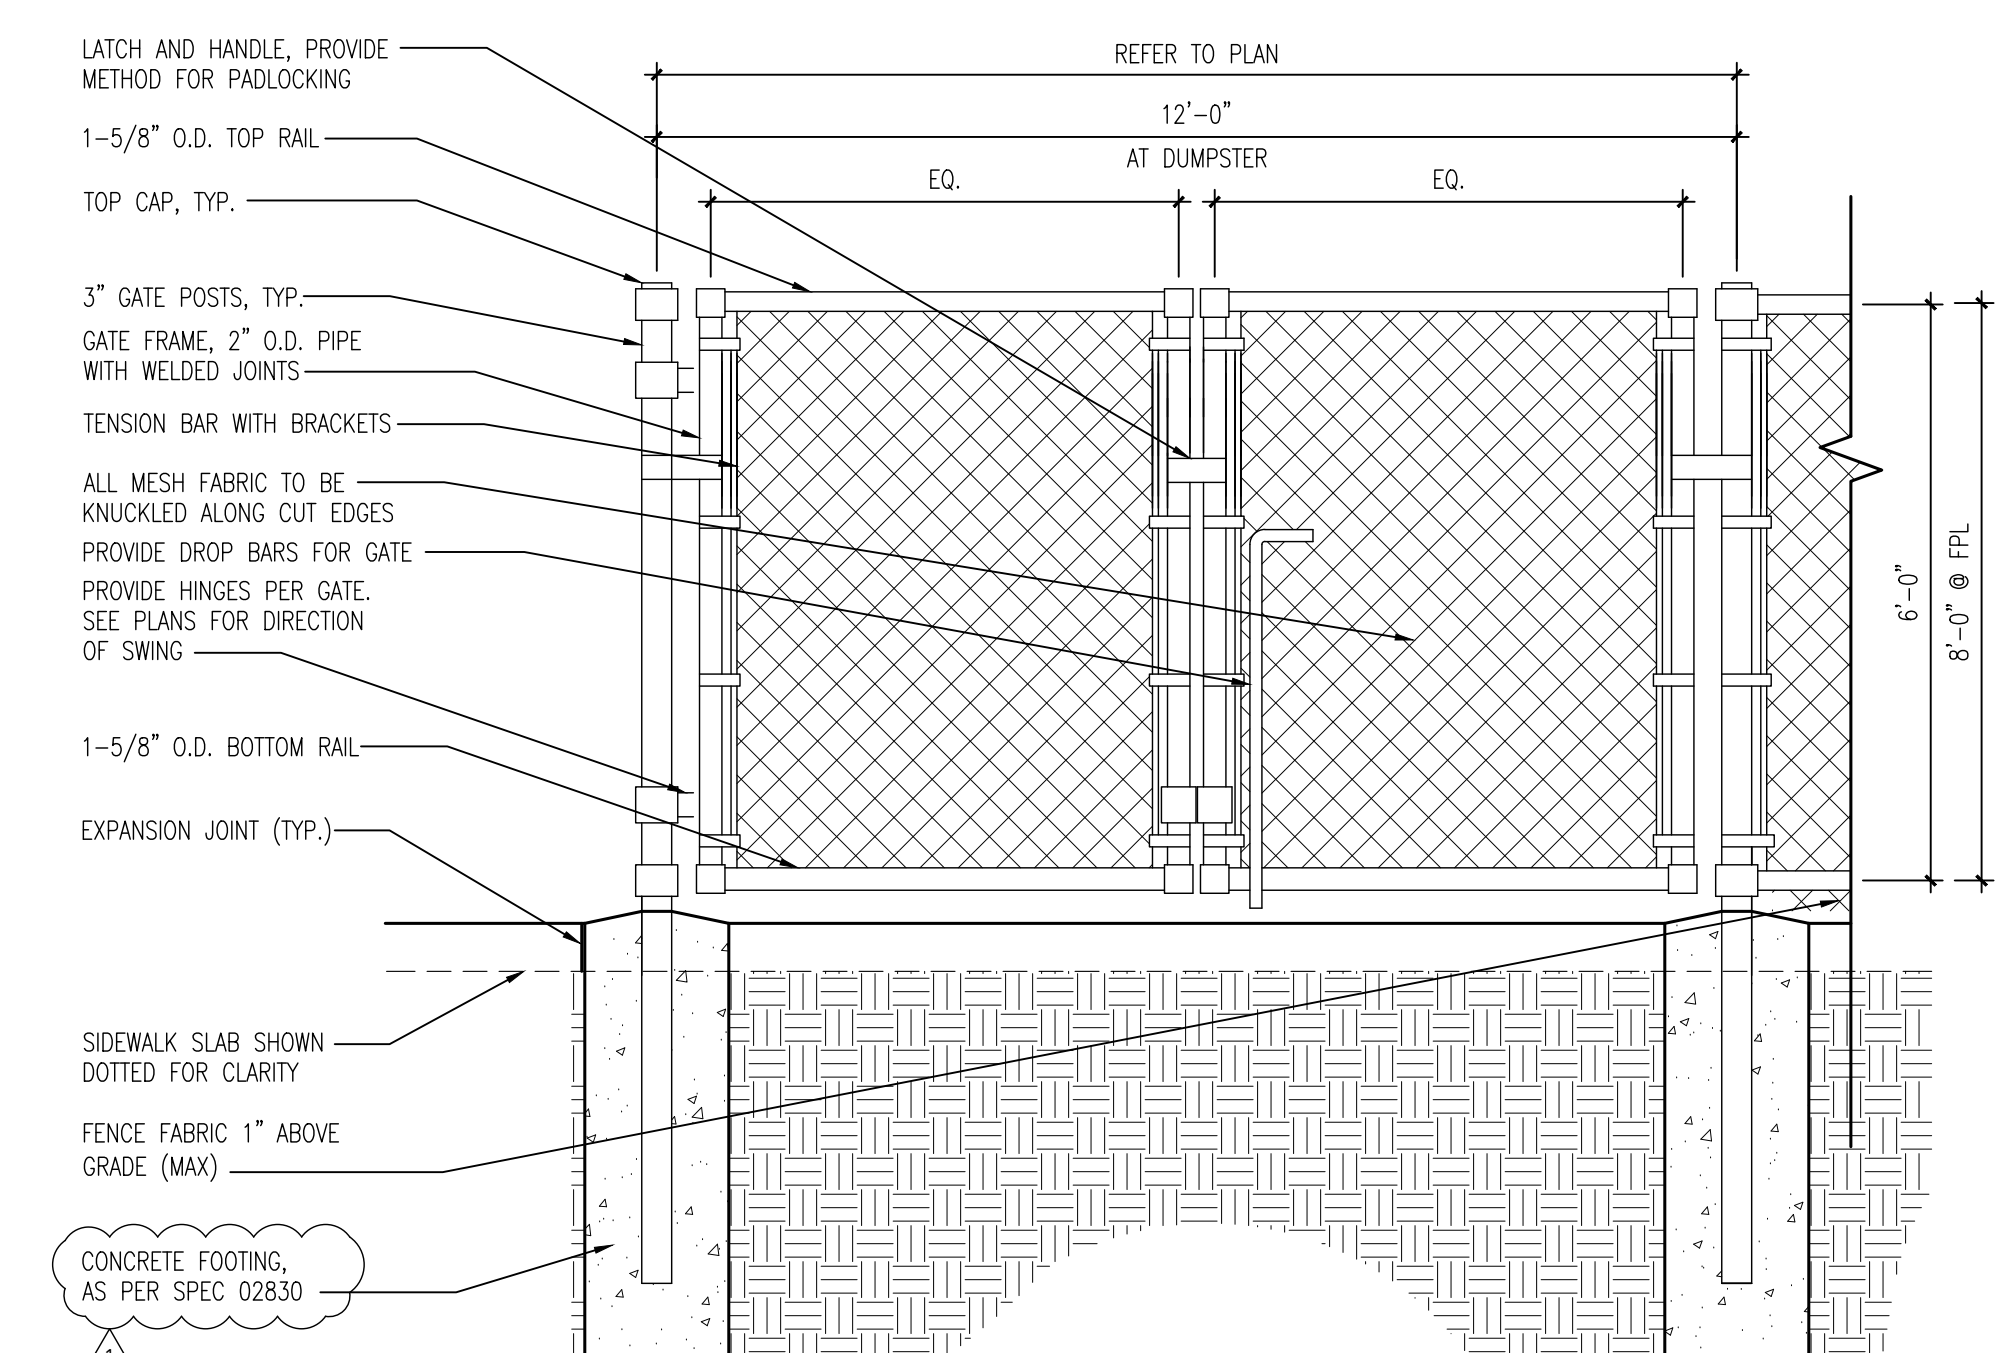


5 SITE FENCING DETAIL
A-111 Scale: 3/4" = 1'-0"

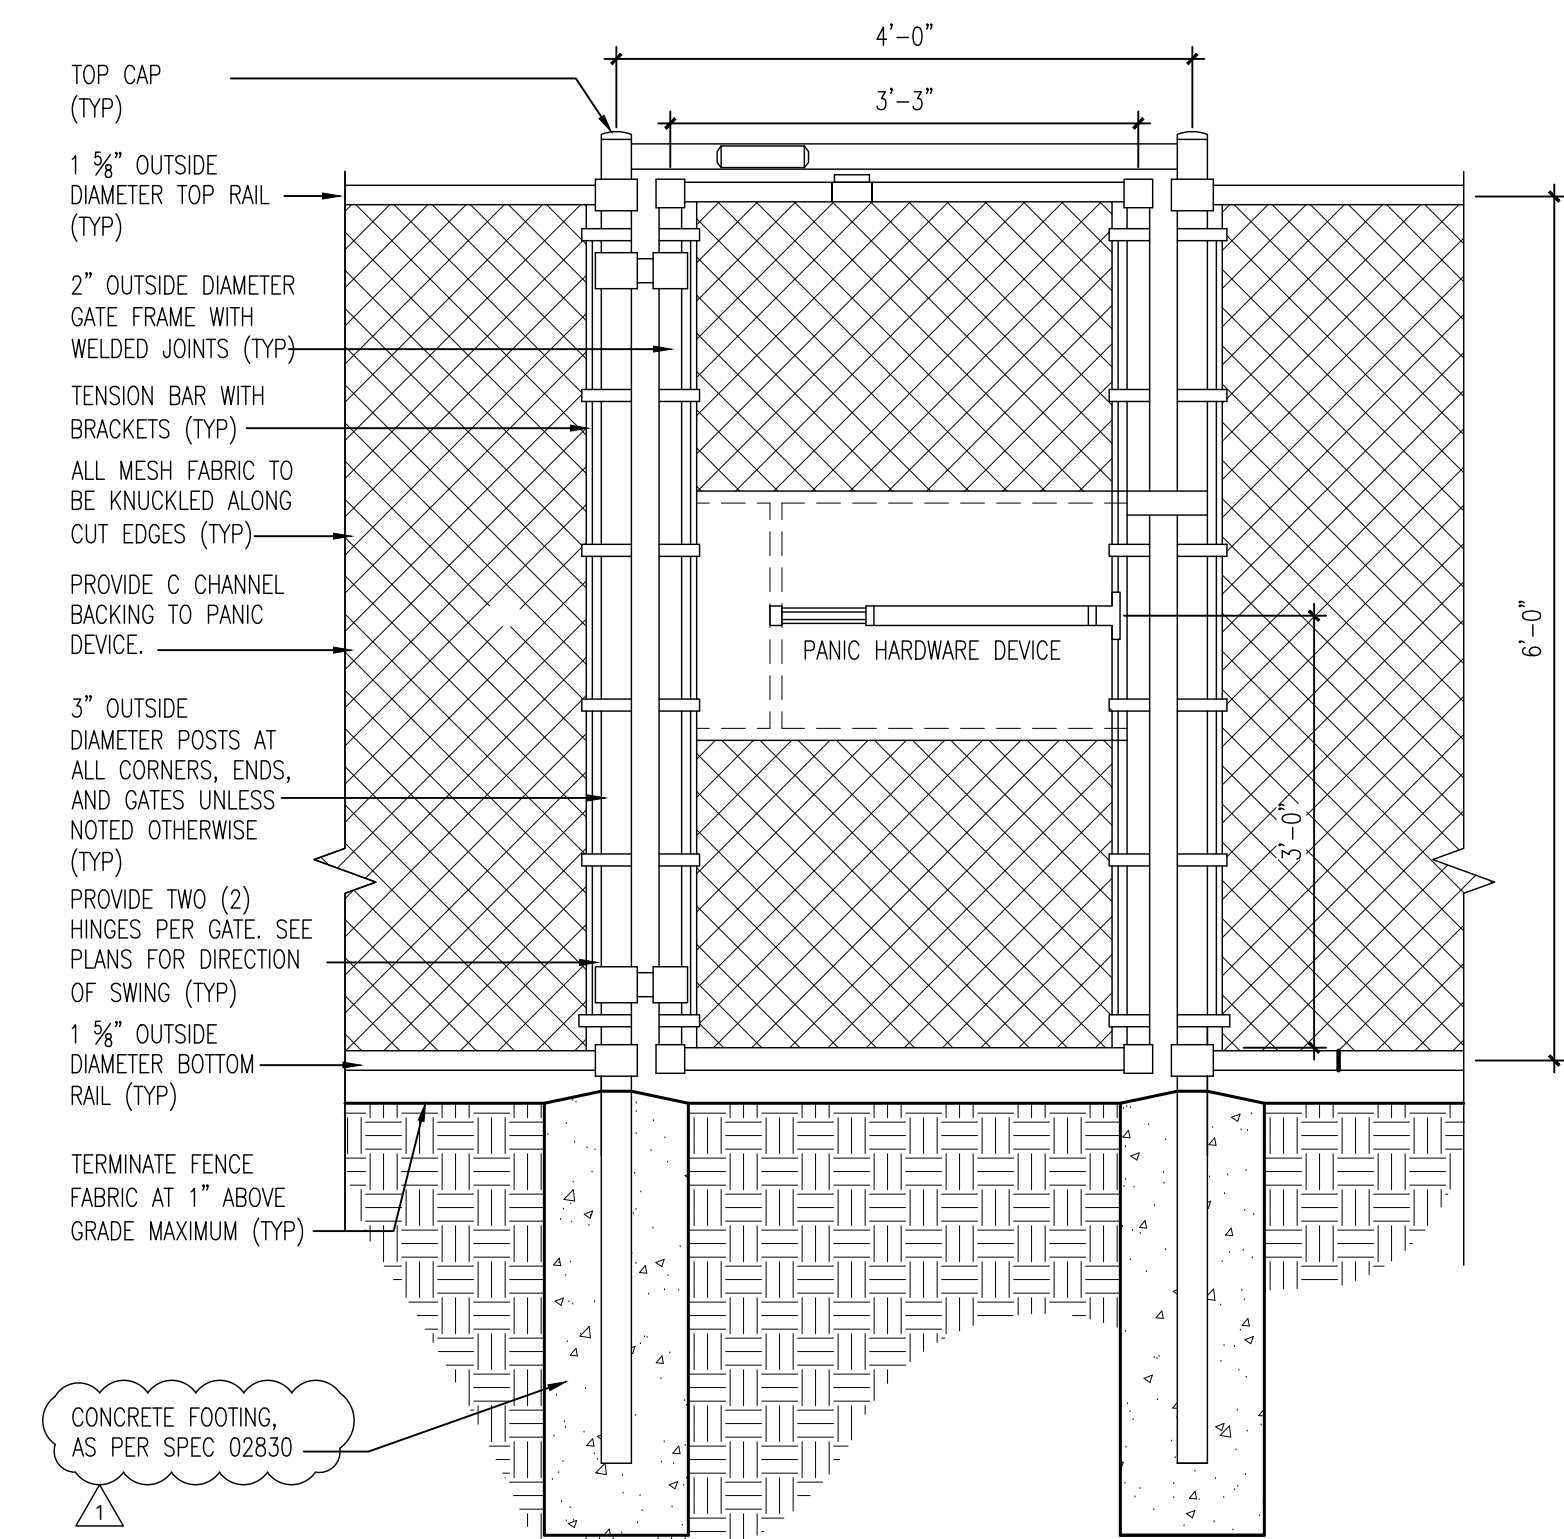

1 SITE FENCING
A-111 Scale: 1/2" = 1'-0"


CHECKED BY: LR. DRAWN BY: CV.

CONSULTANT INFO:

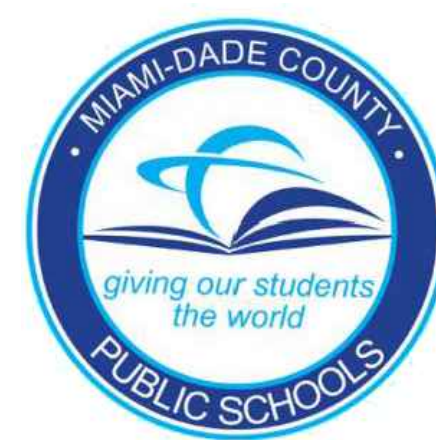


NEW ELEMENTARY SCHOOL (K-5)
VENETIAN PARC WEST
SOUTHWEST 157th AVENUE and 174th STREET
MIAMI, FL. 33187
MDCPS PROJECT No. 01892600

KEY PLAN

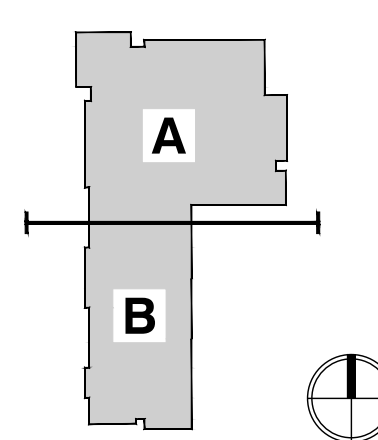

CONSULTANT INFO:

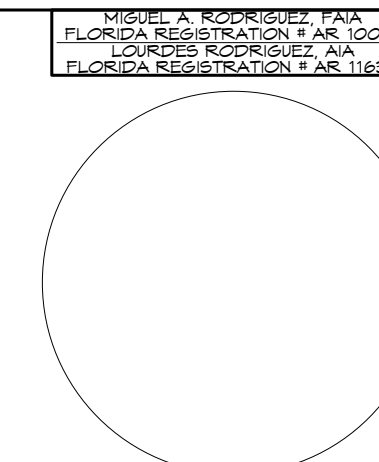

RODRIGUEZ ARCHITECTS INCORPORATED
2121 PONCE DE LEON BLVD. STE. 1010
CORAL GABLES, FL. 33134
TEL: (305) 448-3373
FAX: (305) 448-3374
A A C — 0 0 1 9 3 3



REVISIONS:

02.14.2020 BUILDING DEPARTMENT COMMENTS

DRAWING TITLE:

SITE DETAILS

SCALE AS NOTED

ISSUE DATE:

12.16.19


SHEET:

1906

PROJECT NO.


1906

A-111

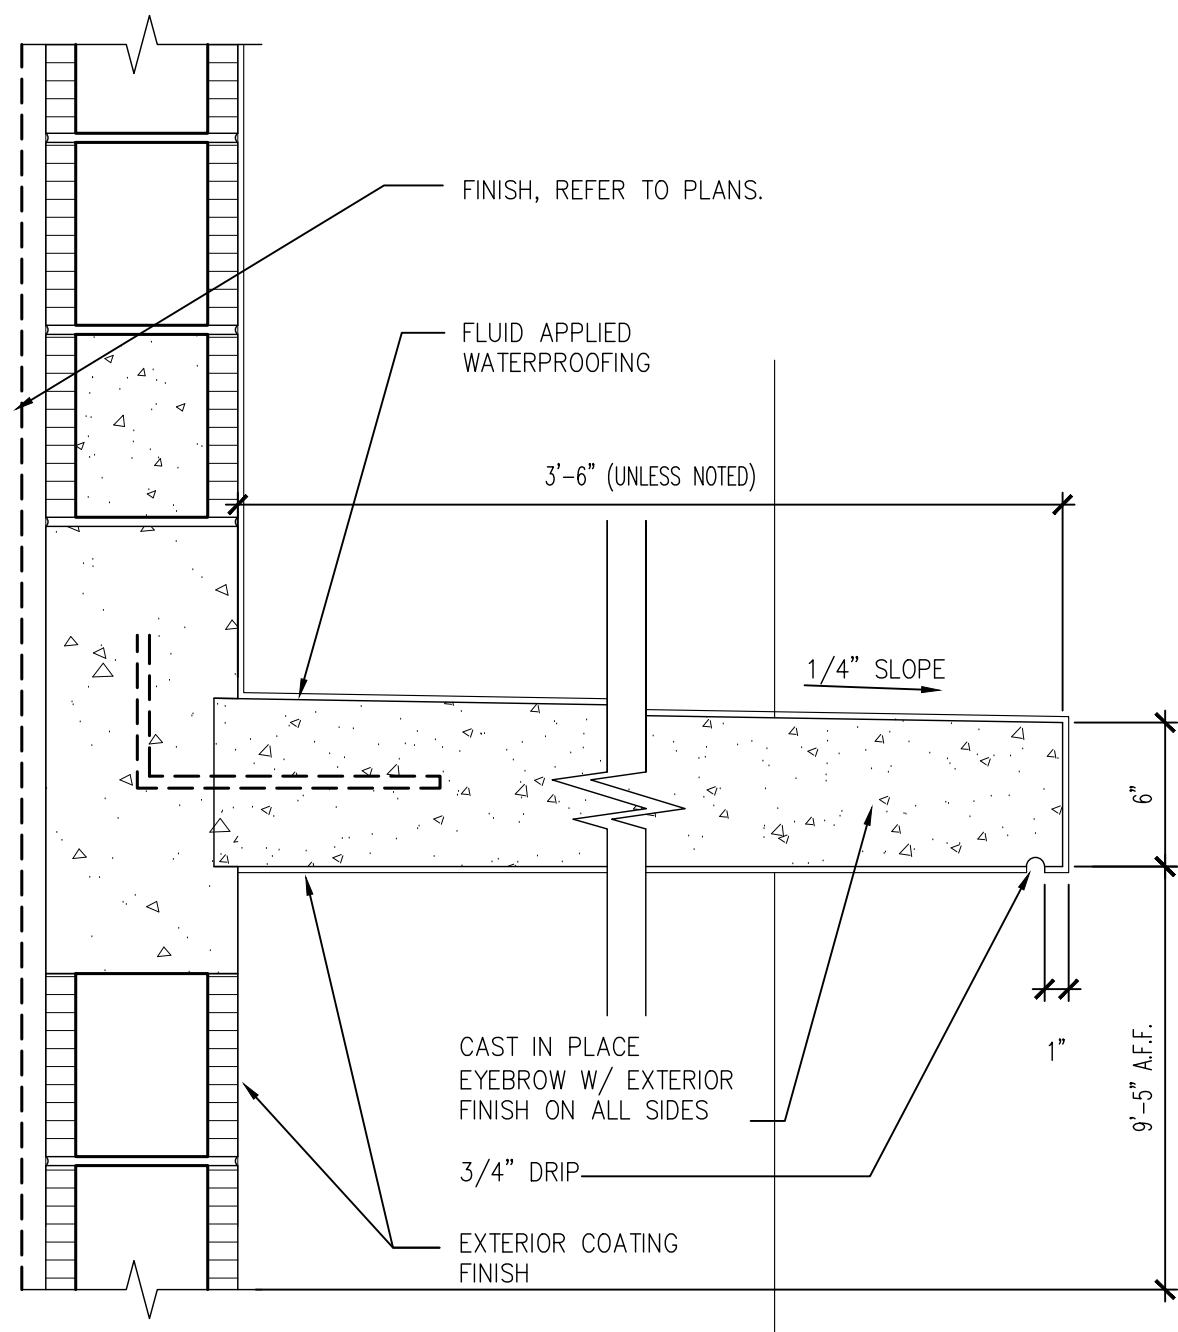


8 CONCRETE EYEBROW
Scale: 1 1/2"=1'-0"


- NOTES:**
1. ALL ALUMINUM WALKWAY COVERS TO BE DESIGNED AND DETAILED BY THE ALUMINUM CANOPY MANUF./INSTALLER SPECIALTY ENGINEER IN ACCORDANCE WITH SPECIFICATIONS. ENGINEERED SHOP DRAWINGS AND CALCS. ARE TO BE DESIGNED, SIGNED AND SEALED BY DELEGATED FLORIDA REGISTERED STRUCTURAL ENGINEER.
 2. ALL WALKWAY COVERS AND PLAY SURFACE COVERS ARE TO BE DESIGNED AND CONSTRUCTED IN ACCORDANCE WITH ALL APPLICABLE CODES INCLUDING CURRENT EDITION OF FLORIDA BUILDING CODE AND ASCE 7.
 3. SUBMIT SHOP DRAWINGS FOR A/E TO REVIEW AND APPROVE PRIOR TO FABRICATION.
 4. CONTRACTOR TO COORDINATE WITH ELECTRICAL DRAWINGS FOR ALL LIGHT FIXTURE LOCATIONS AND INSTALLATIONS.
 5. DRAINAGE OUTLETS AND WEEP HOLES MAY VARY AS FINISHED GRADE VARIES. WEEP HOLES SHALL BE 6" FROM HIGHEST FINISHED GRADE ONLY. CONTRACTOR TO COORDINATE WITH CIVIL DRAWINGS FOR ALL CONNECTIONS TO STORM DRAINAGE.
 6. TO PREVENT LEAKAGE, ALL FASTENERS FOR ELECTRICAL CONDUIT SHALL BE ON DRY COLUMNS AND DECK LIDS.
 7. CONCEAL ALL EXPOSED CONDUITS.

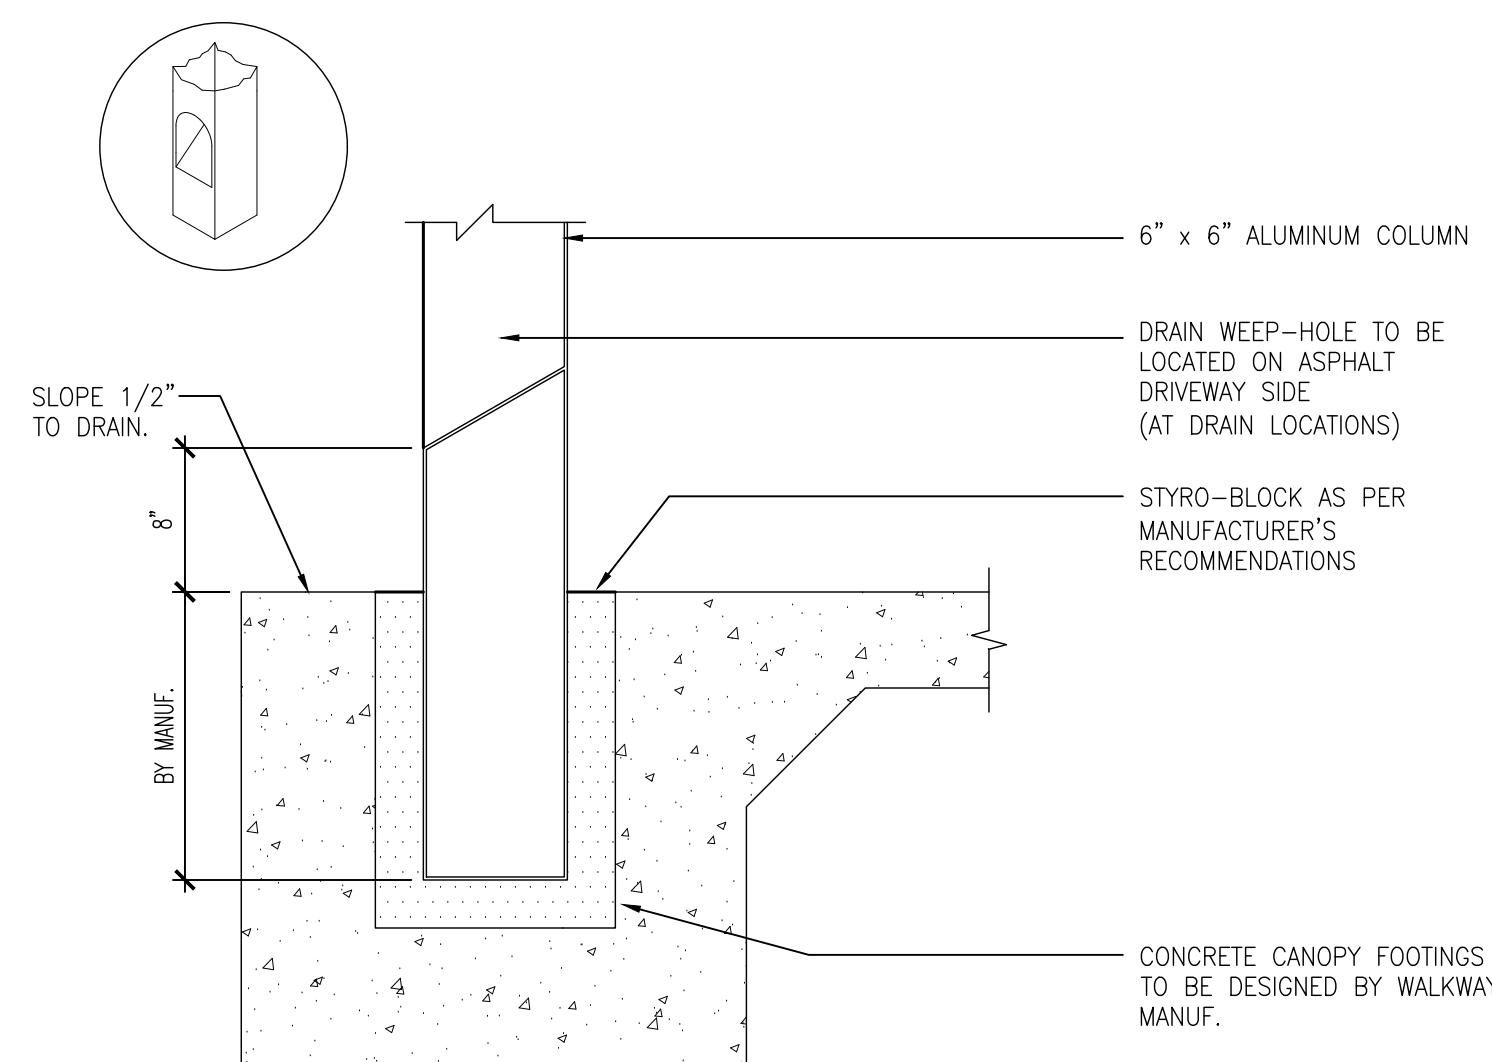


6 CANOPY DETAIL
A-112 Scale: 1 1/2"=1'-0"

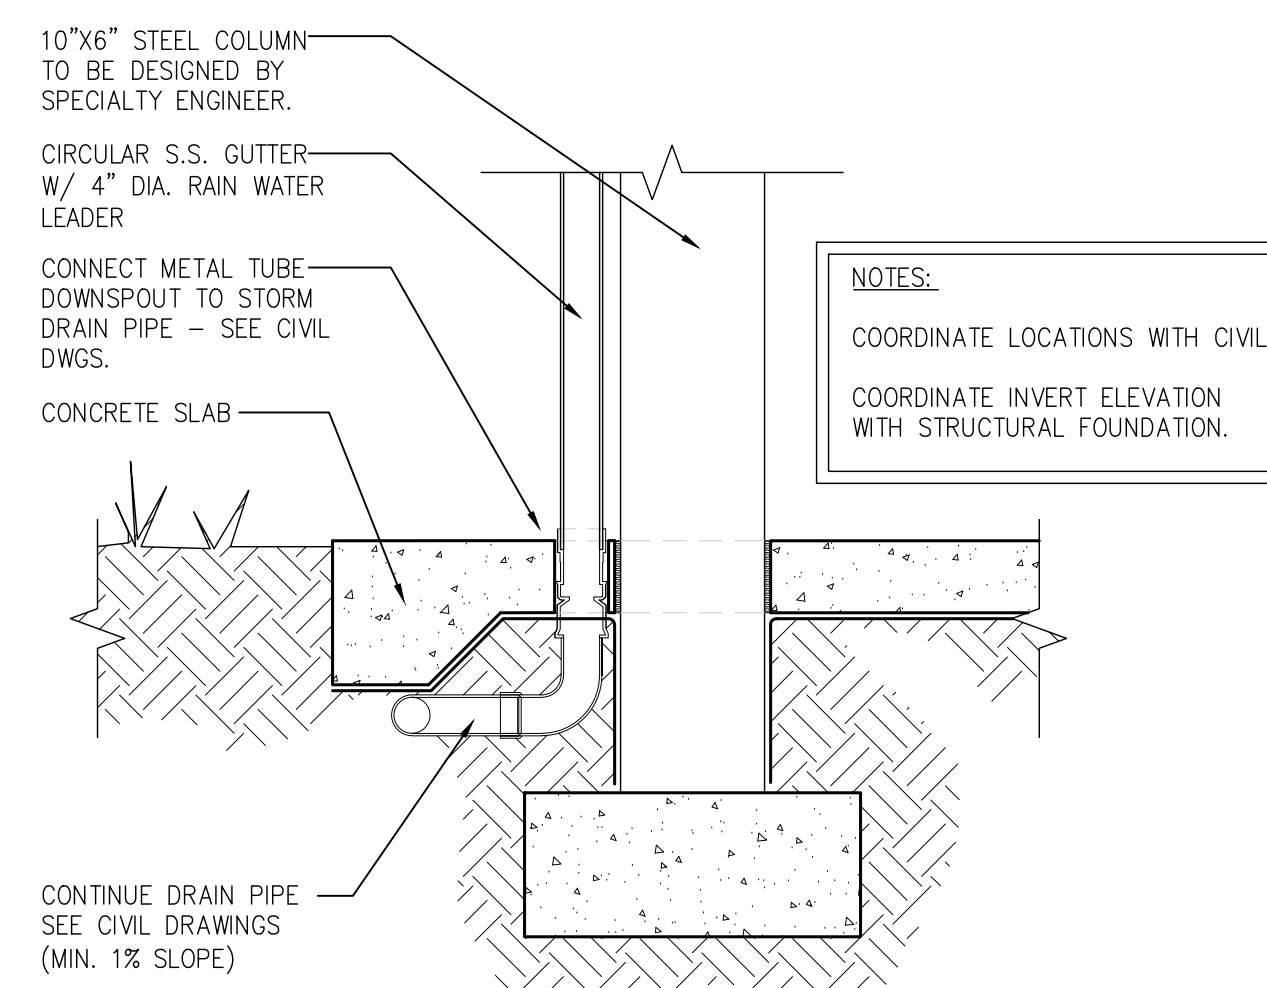


5 RAIN WATER LEADER CONNECTION
A-112 Scale: 3/4"=1'-0"

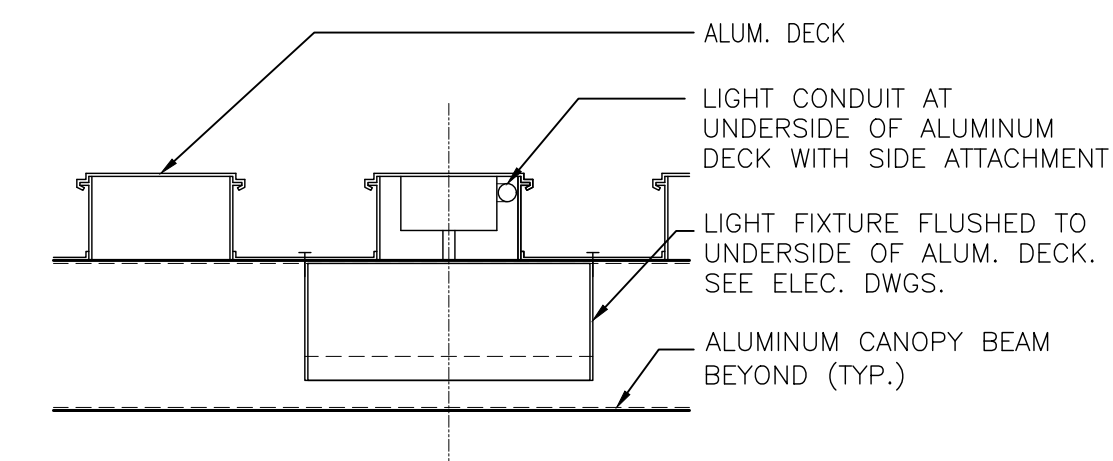



4 CANOPY DETAIL
A-112 Scale: 1 1/2"=1'-0"

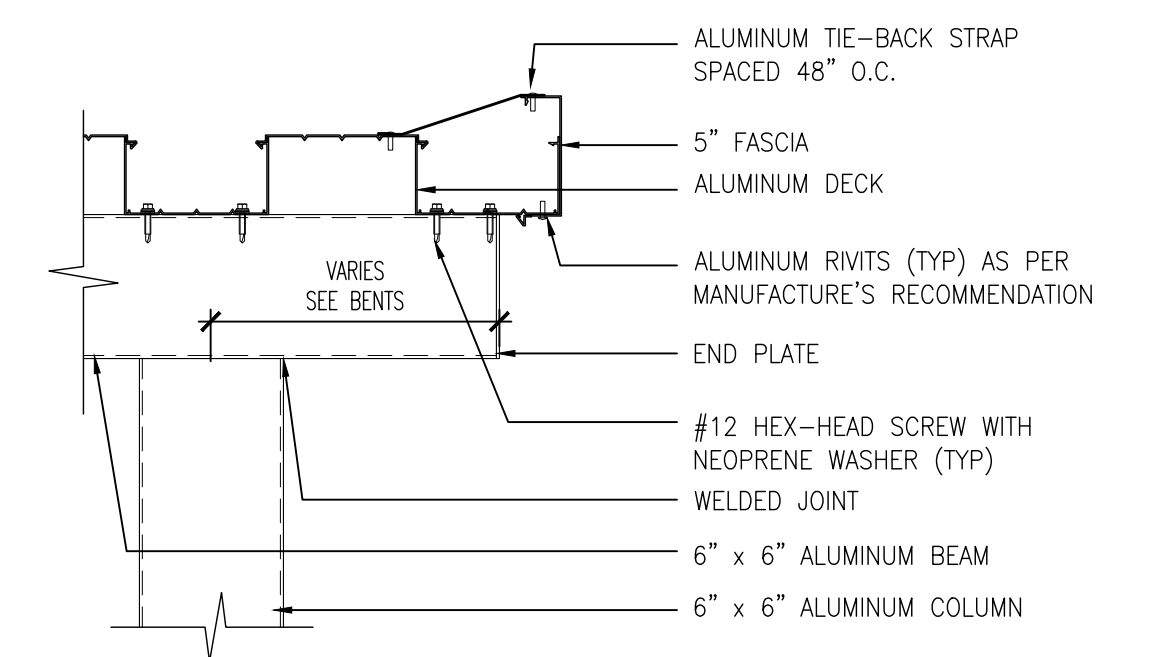

3 CANOPY DETAIL
A-112 Scale: 1 1/2"=1'-0"

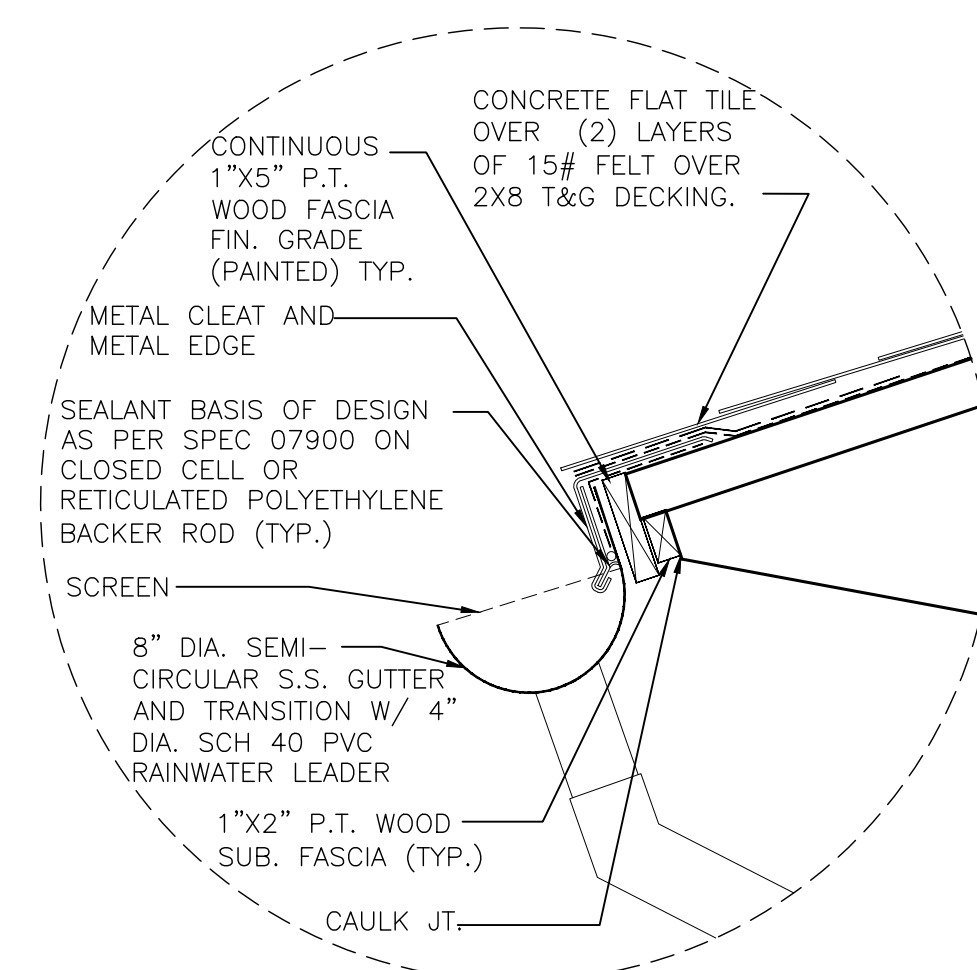


2 CANOPY DETAIL @ P.E. SHELTER
A-112 Scale: 1/2"=1'-0"

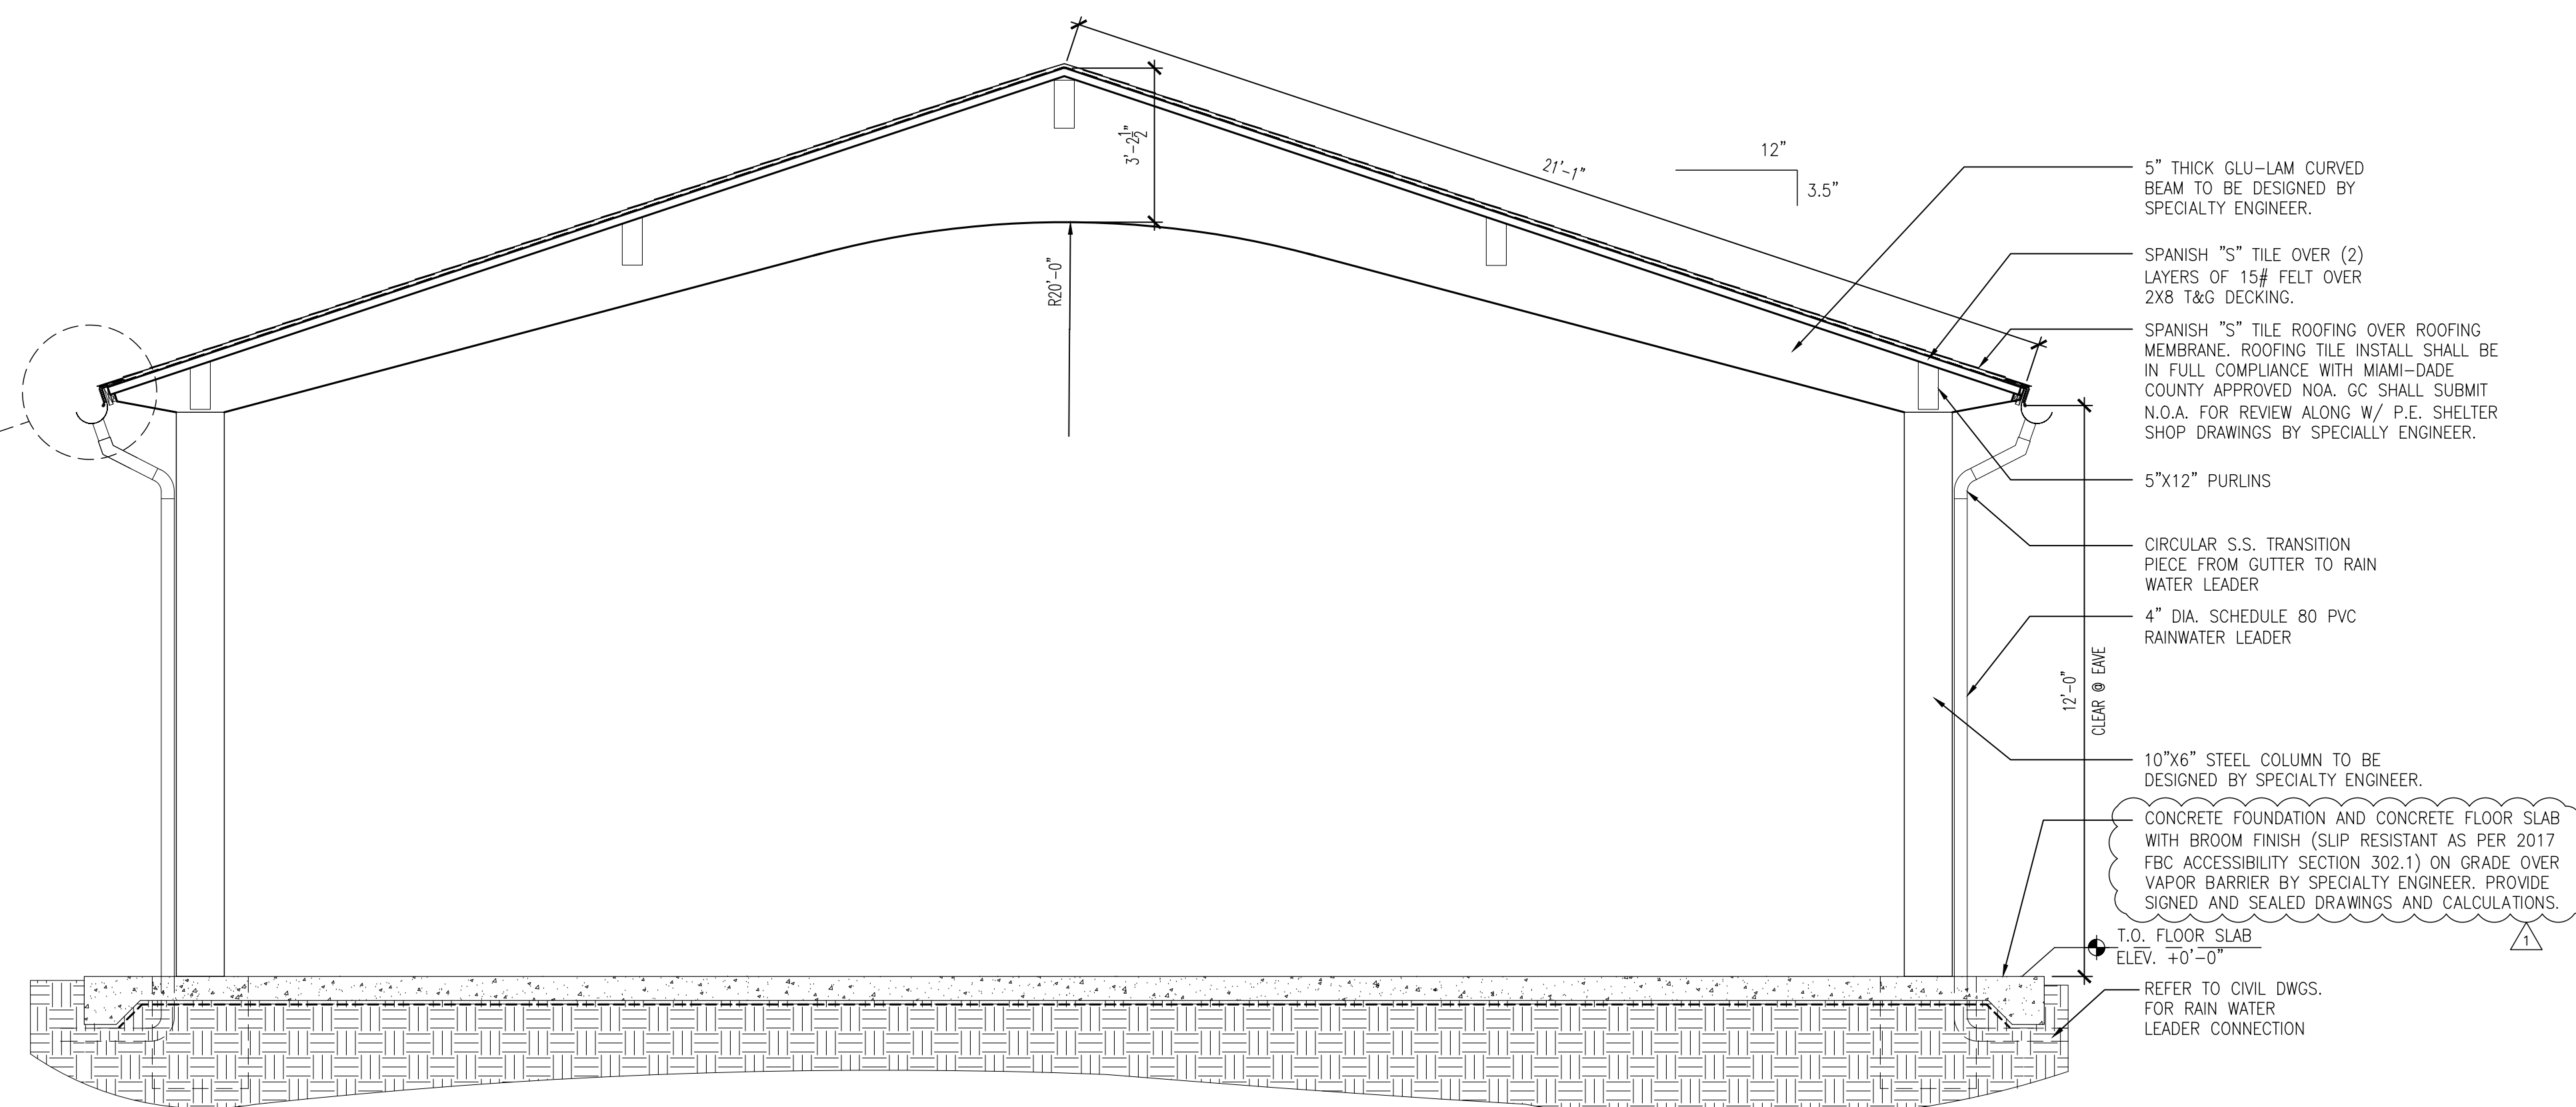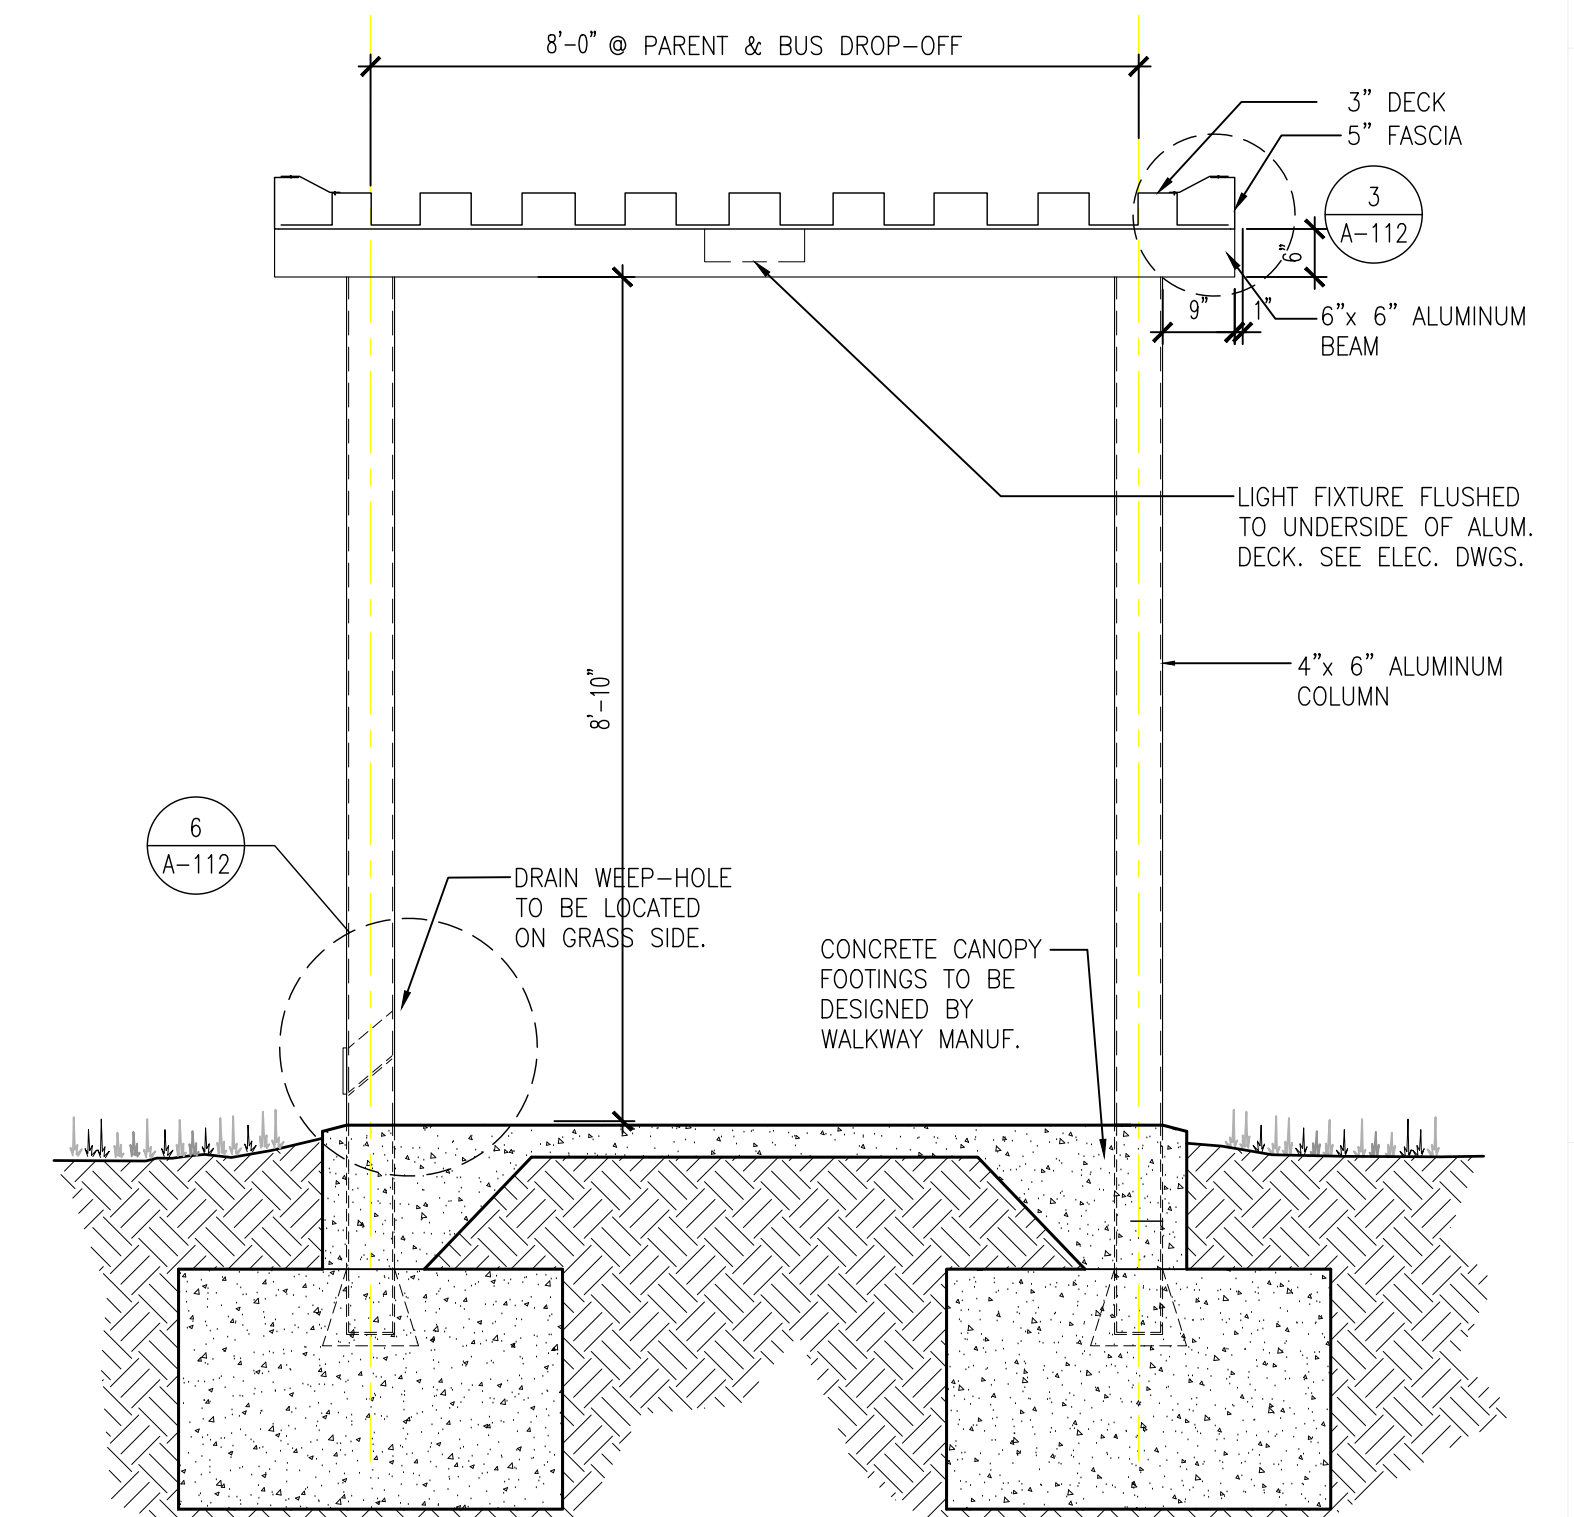

1 CANOPY DETAIL @ COVERED WALKWAY
A-112 Scale: 1/2"=1'-0"


CHECKED BY: LR	DRAWN BY: C.V.
-------------------	-------------------

CONSULTANT INFO:

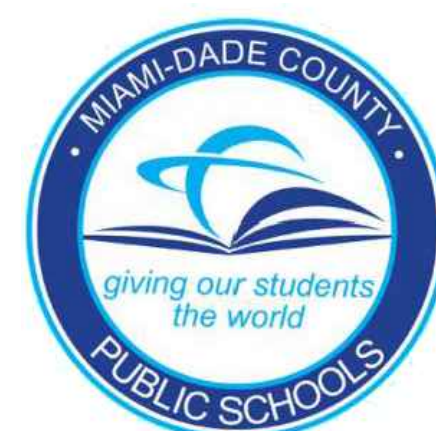

NEW ELEMENTARY SCHOOL (K-5)
VENETIAN PARC WEST
SOUTHWEST 157th AVENUE and 174th STREET
MIAMI, FL. 33187
MDCPS PROJECT No. 01892600

KEY PLAN

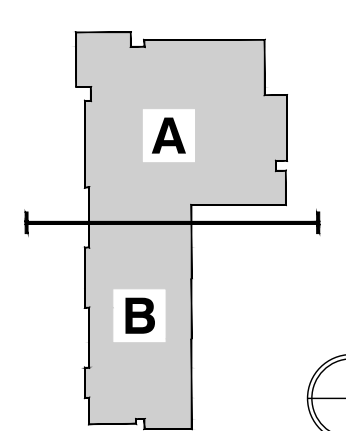

CONSULTANT INFO:

RODRIGUEZ ARCHITECTS INCORPORATED
2121 PONCE DE LEON BLVD. STE 1010
CORAL GABLES, FL. 33134
TEL: (305) 448-3373
FAX: (305) 448-3374
A A C — 0 0 1 9 3 3

RODRIGUEZ ARCHITECTS INCORPORATED
2121 PONCE DE LEON BLVD. STE 1010
CORAL GABLES, FL. 33134
TEL: (305) 448-3373
FAX: (305) 448-3374
A A C — 0 0 1 9 3 3



REVISIONS:

02/14/2020 BUILDING DEPARTMENT COMMENTS

DRAWING TITLE:

SITE PLAN DETAILS

SCALE AS NOTED

ISSUE DATE:


12/16/19

PROJECT NO:

1906


SHEET:

A-112

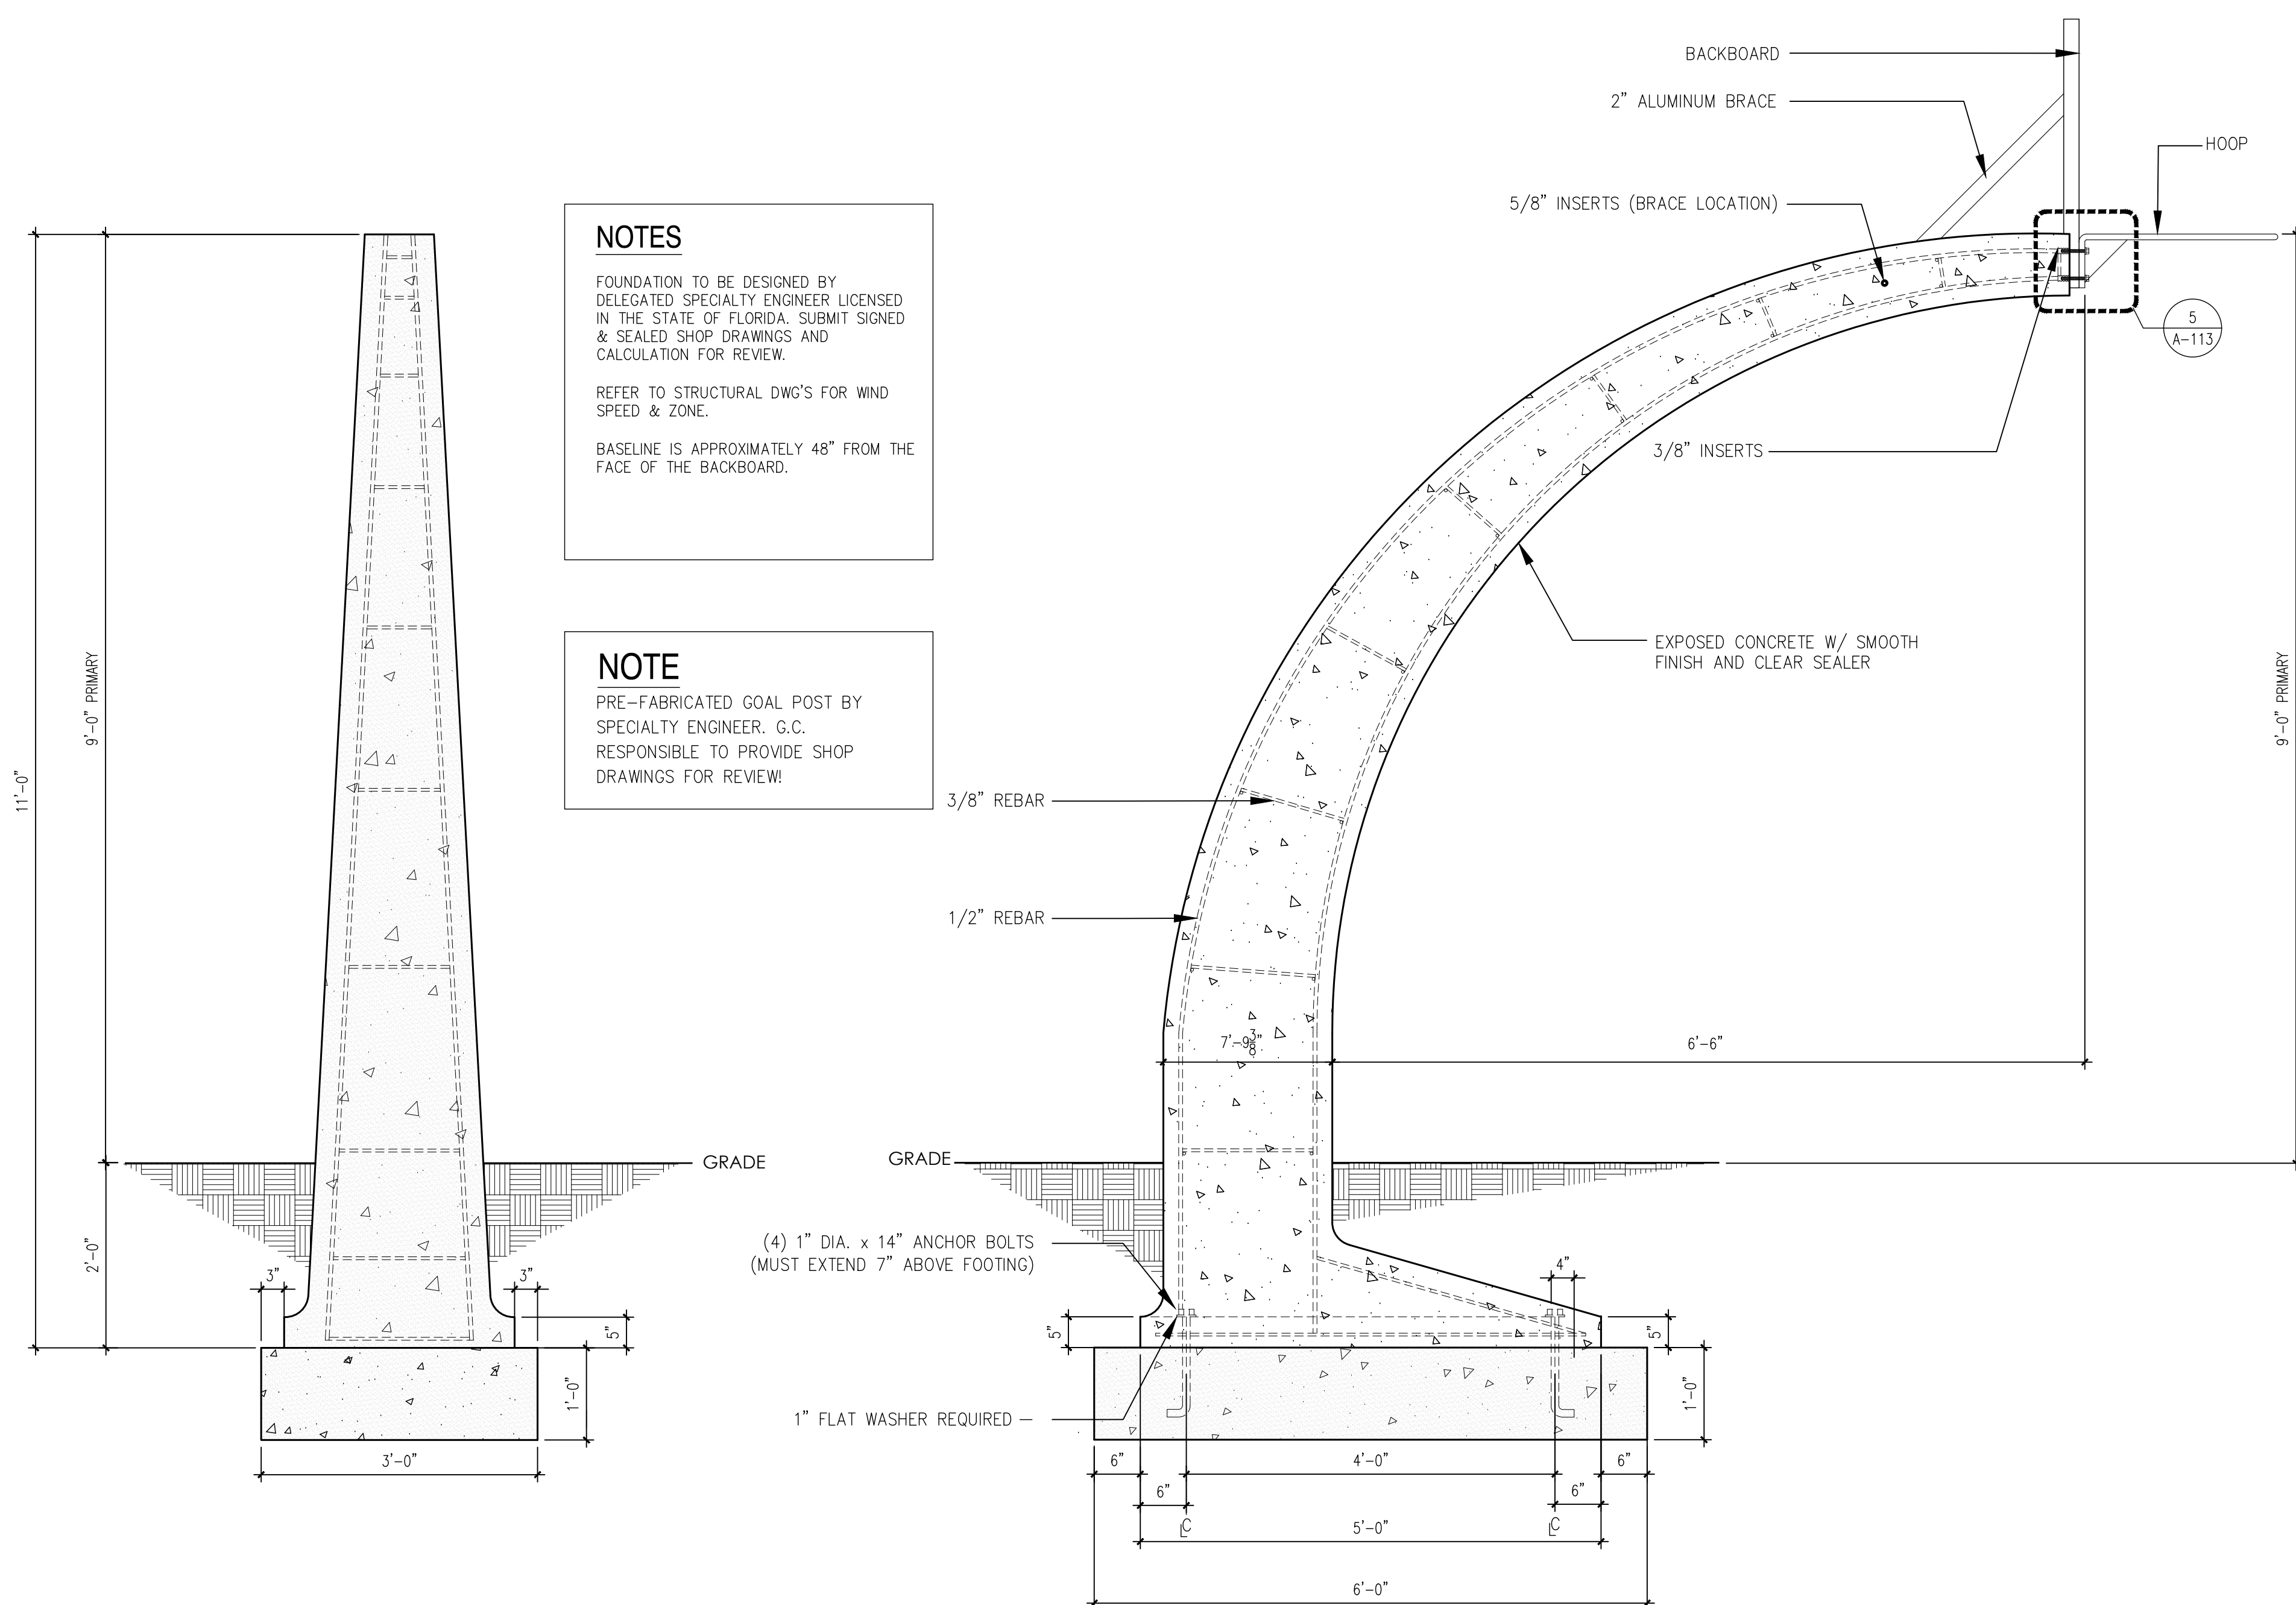


4 BASKETBALL STANDARD SECTION
A-113 Scale: 3/16"=1'-0"

3 BASKETBALL STANDARD SECTION
A-113 Scale: 3/16"=1'-0"

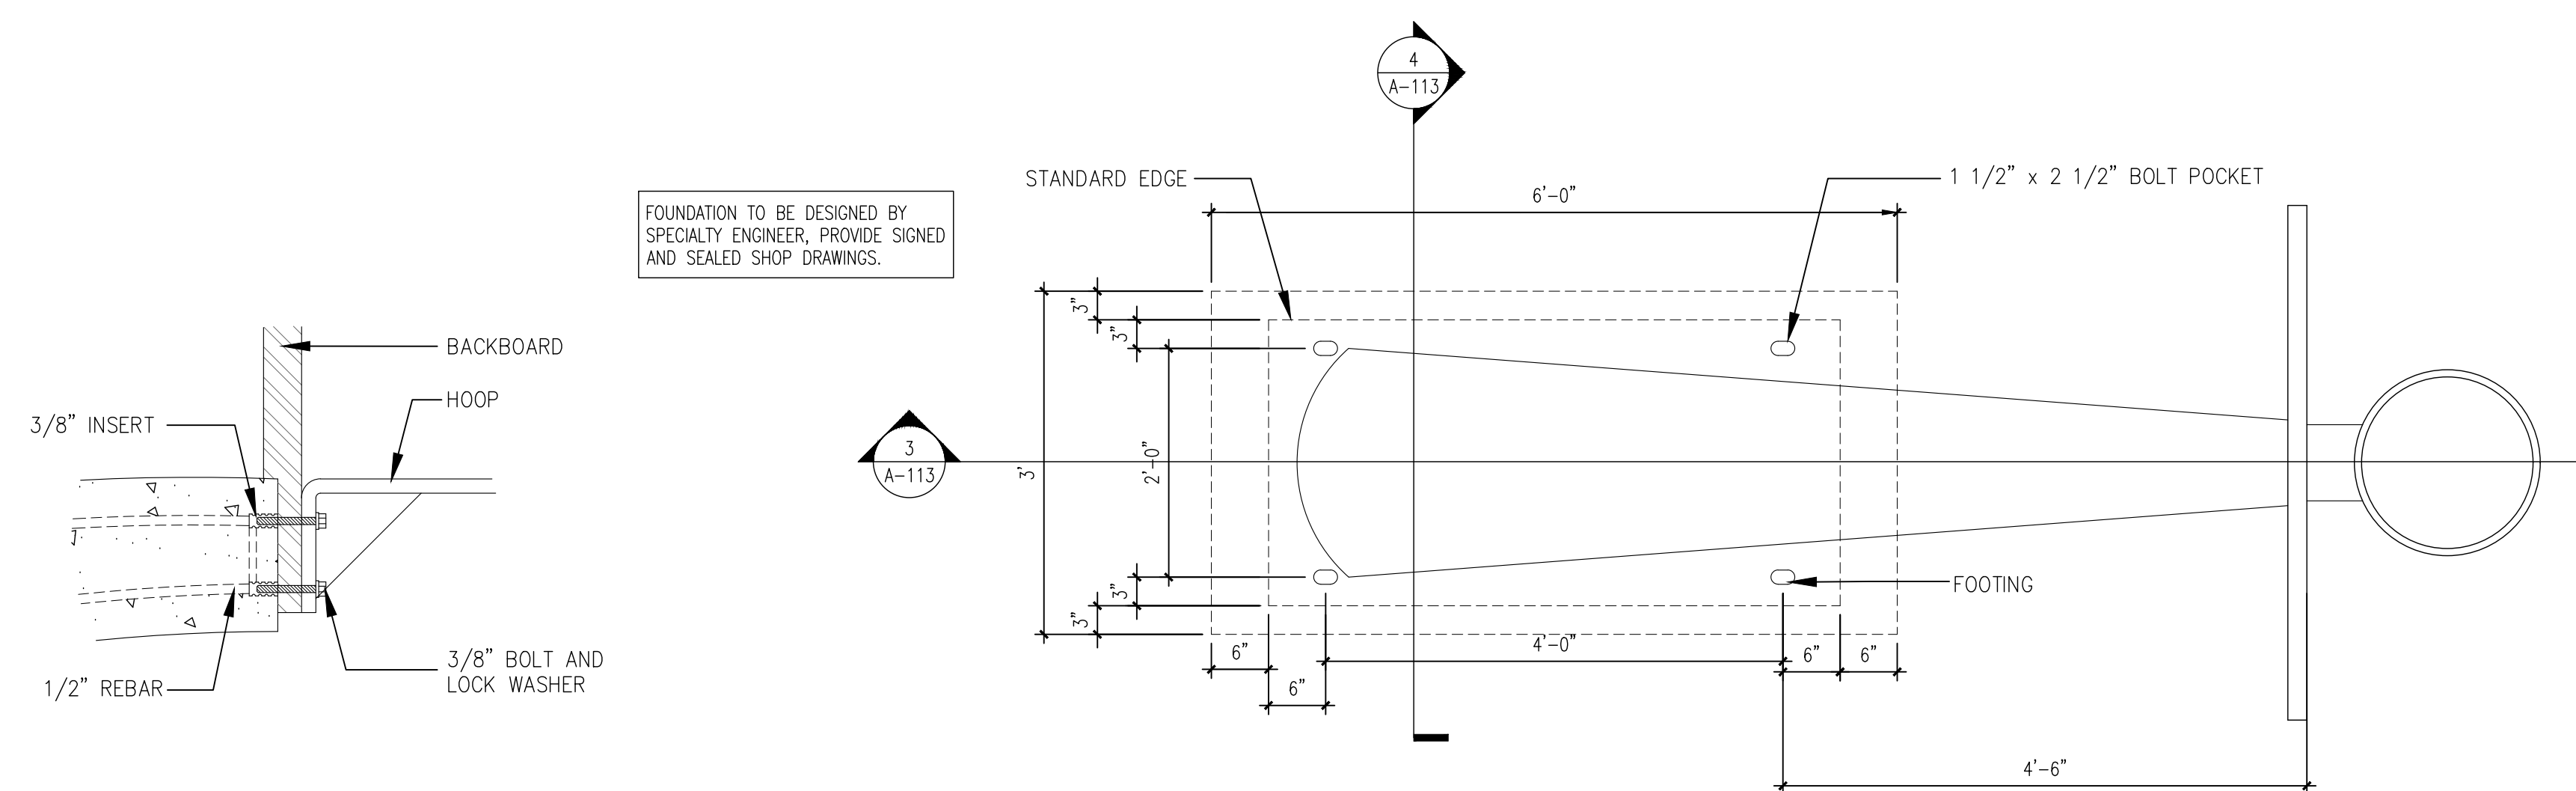


5 BASKETBALL STANDARD DETAIL
A-113 Scale: 3/16"=1'-0"


2 BASKETBALL STANDARD
A-113 Scale: 3/16"=1'-0"

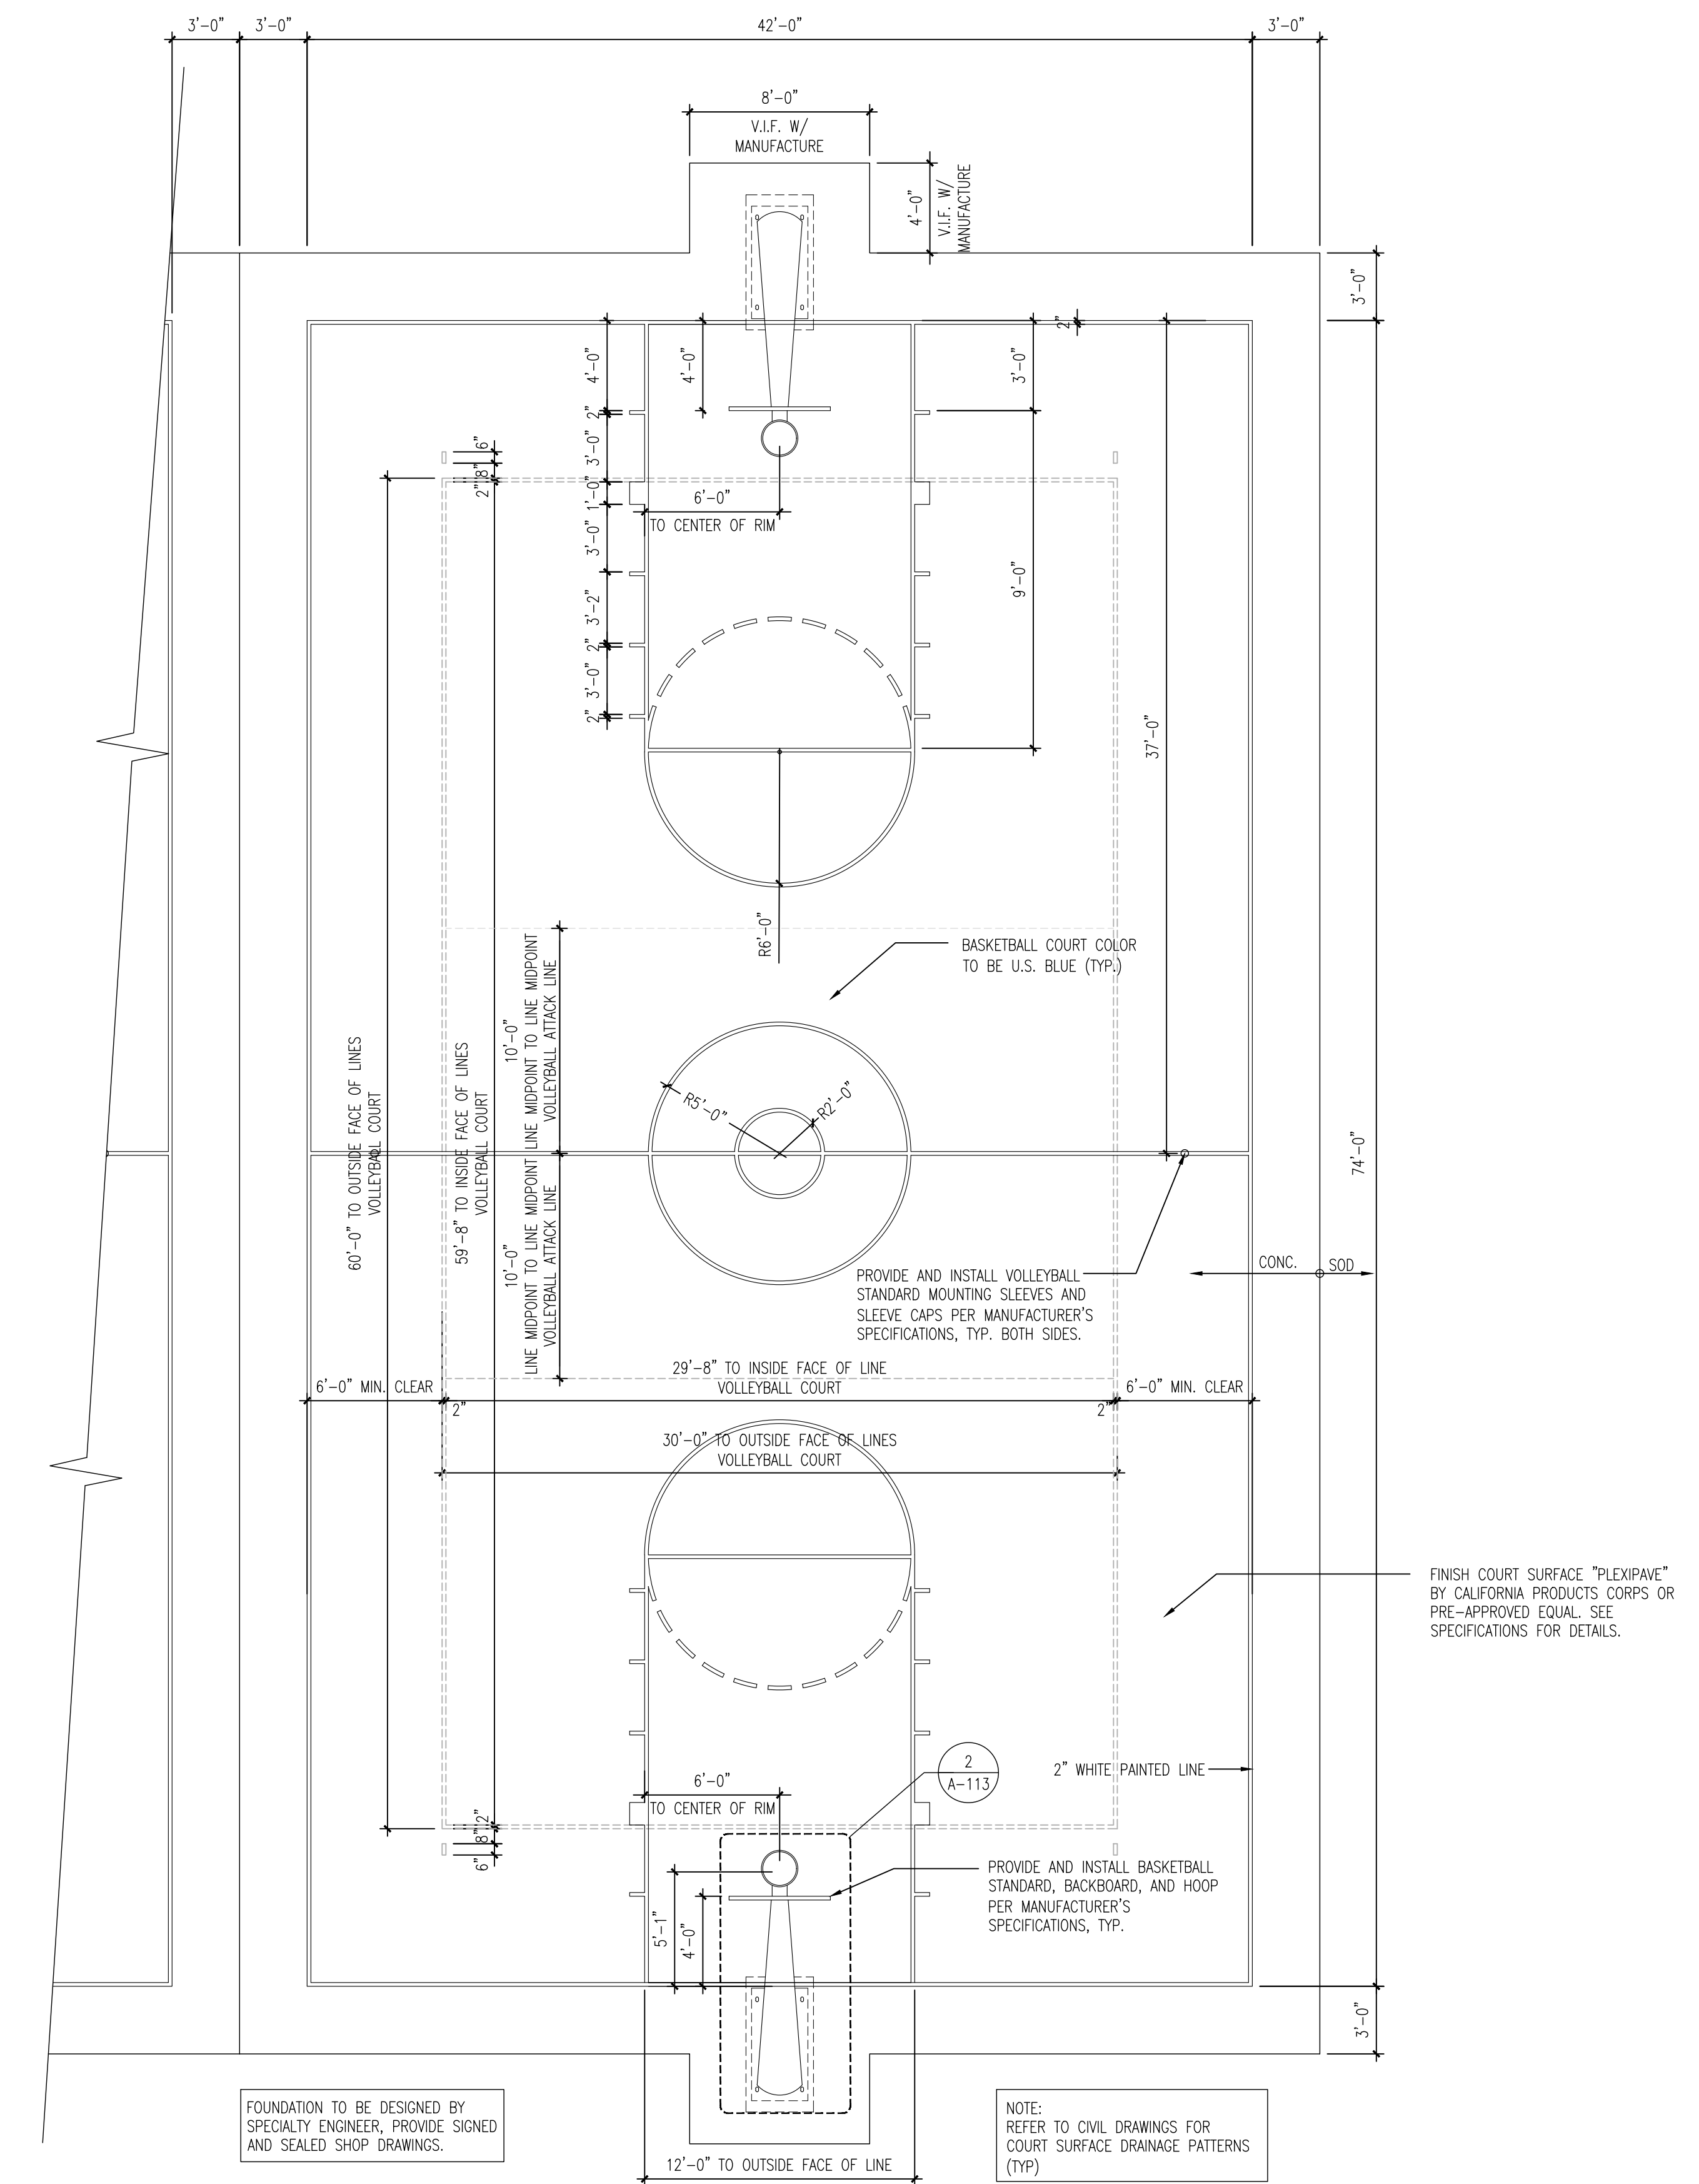

1 ENLARGED BASKETBALL & VOLLEYBALL COURT LAYOUTS
A-113 Scale: 3/16"=1'-0"

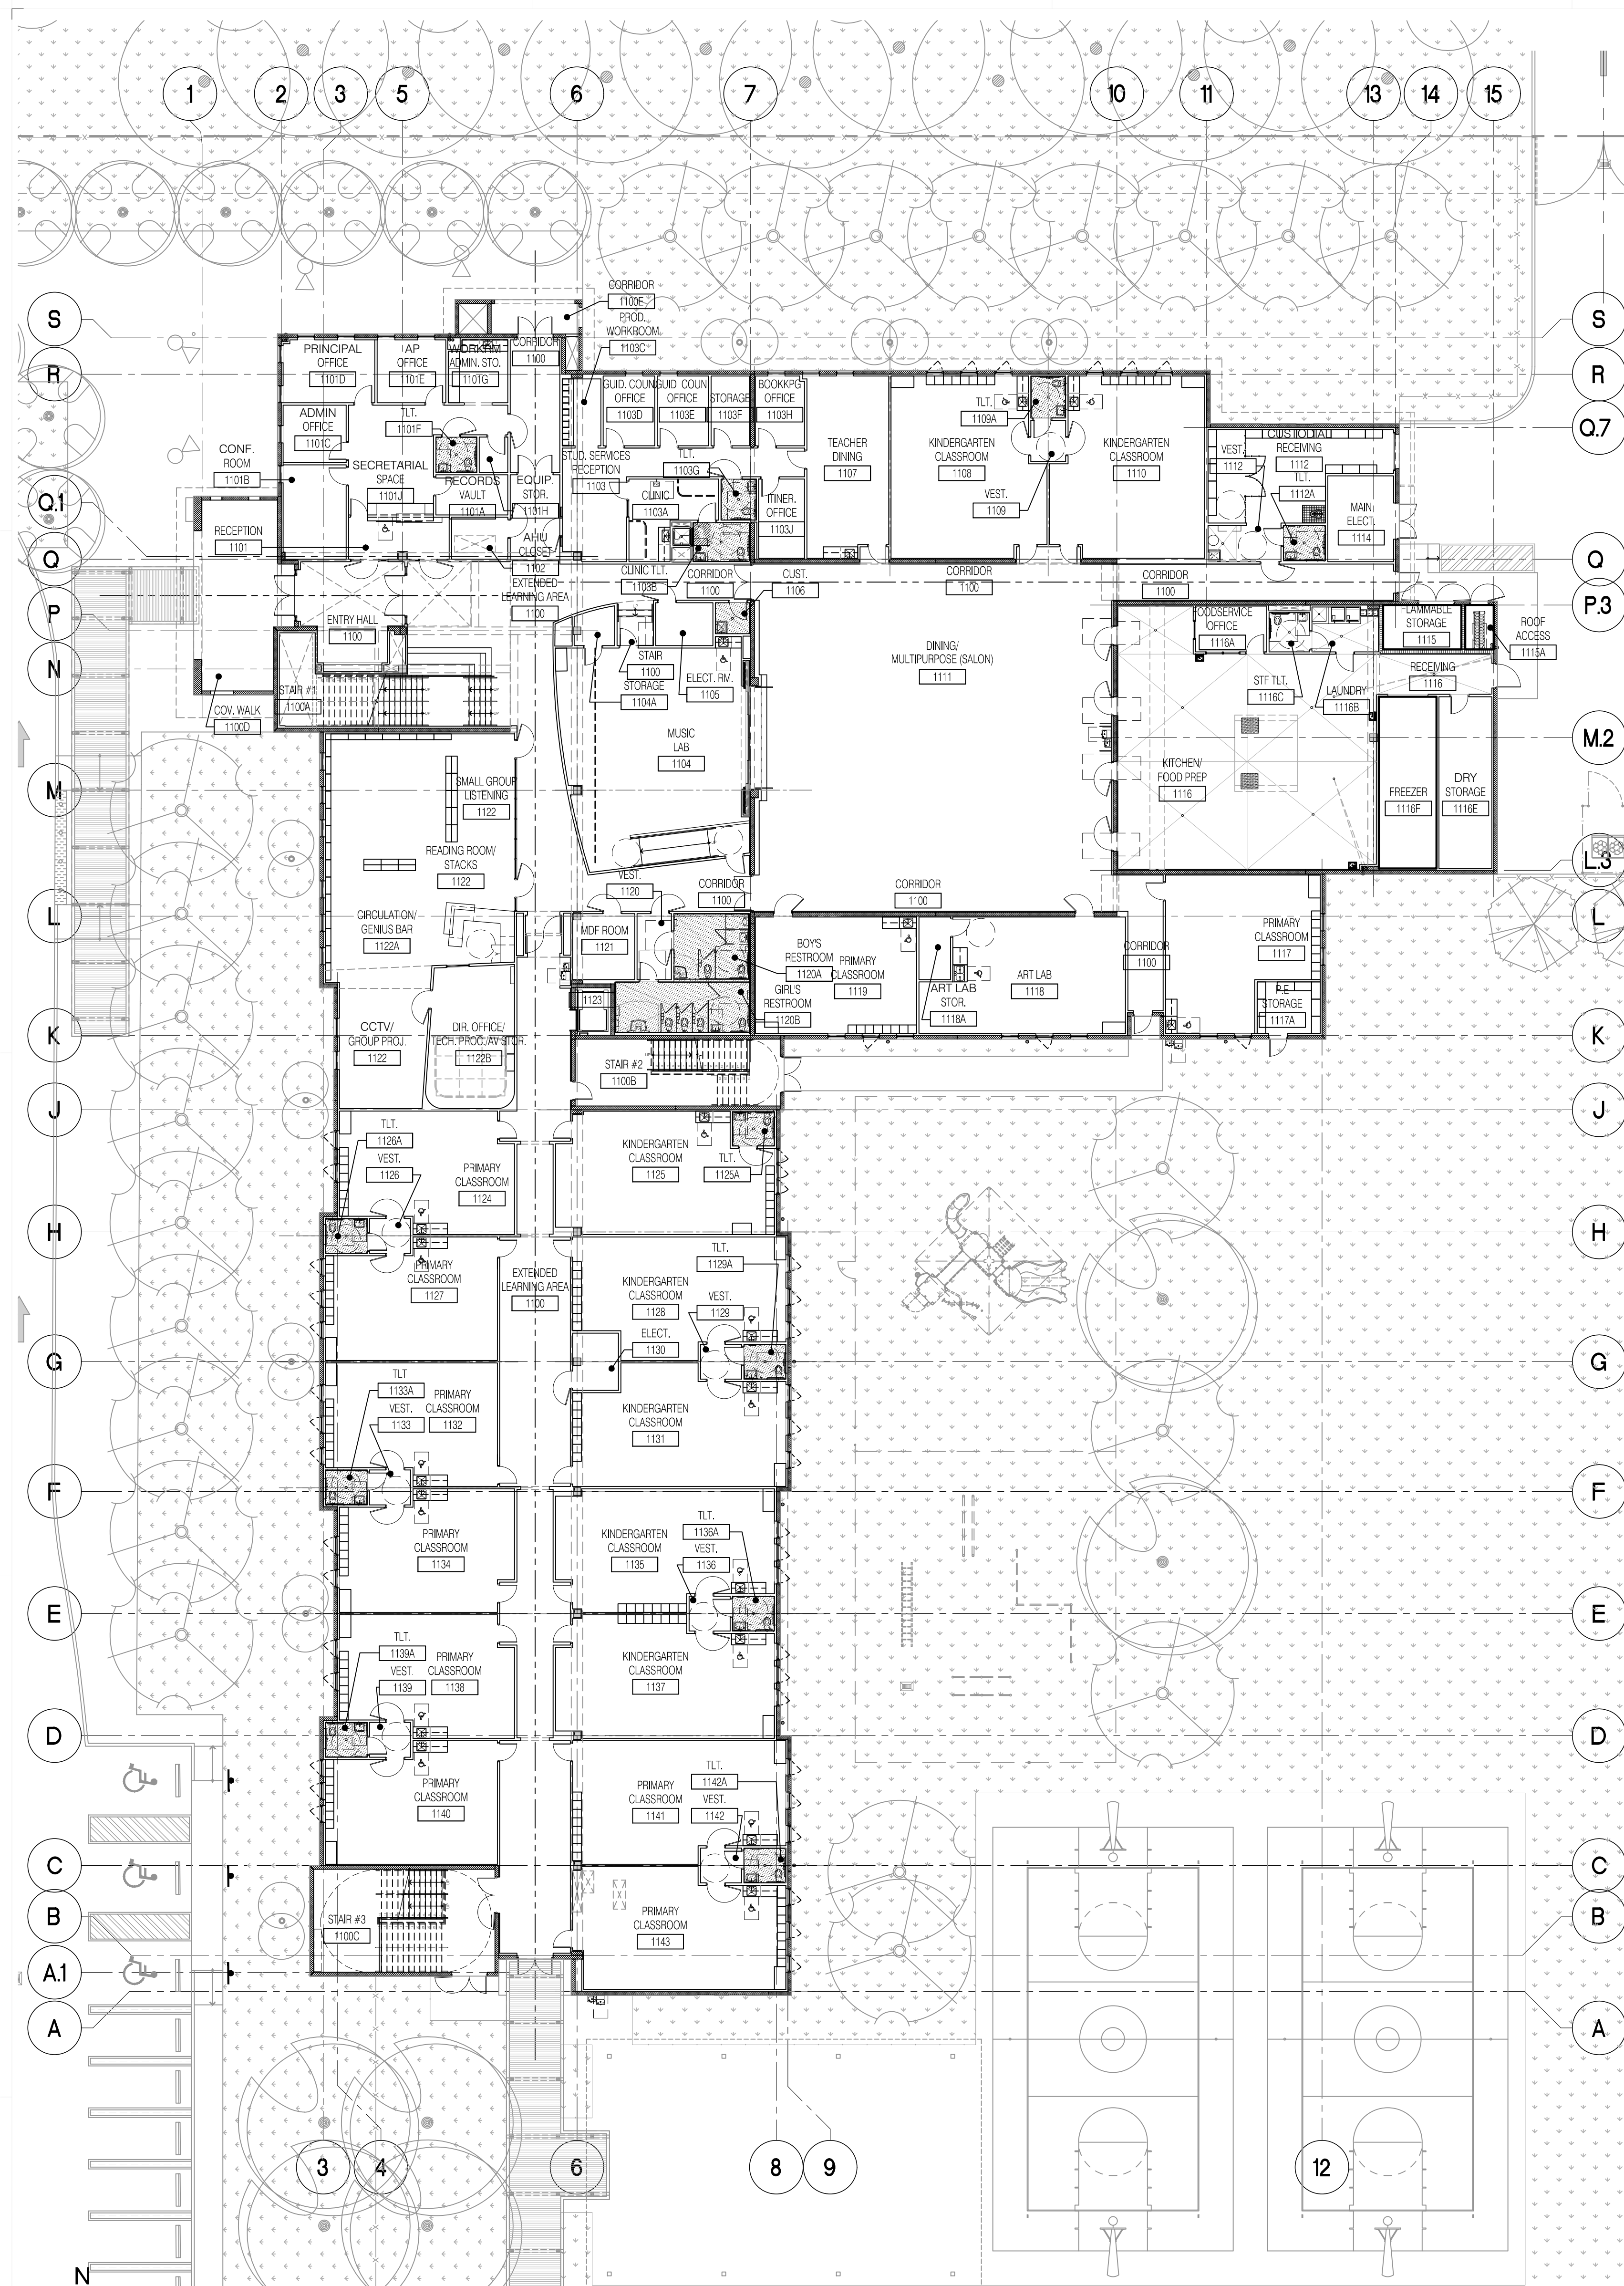

1 OVERALL FIRST FLOOR PLAN
Scale: 1/16" = 1'-0"

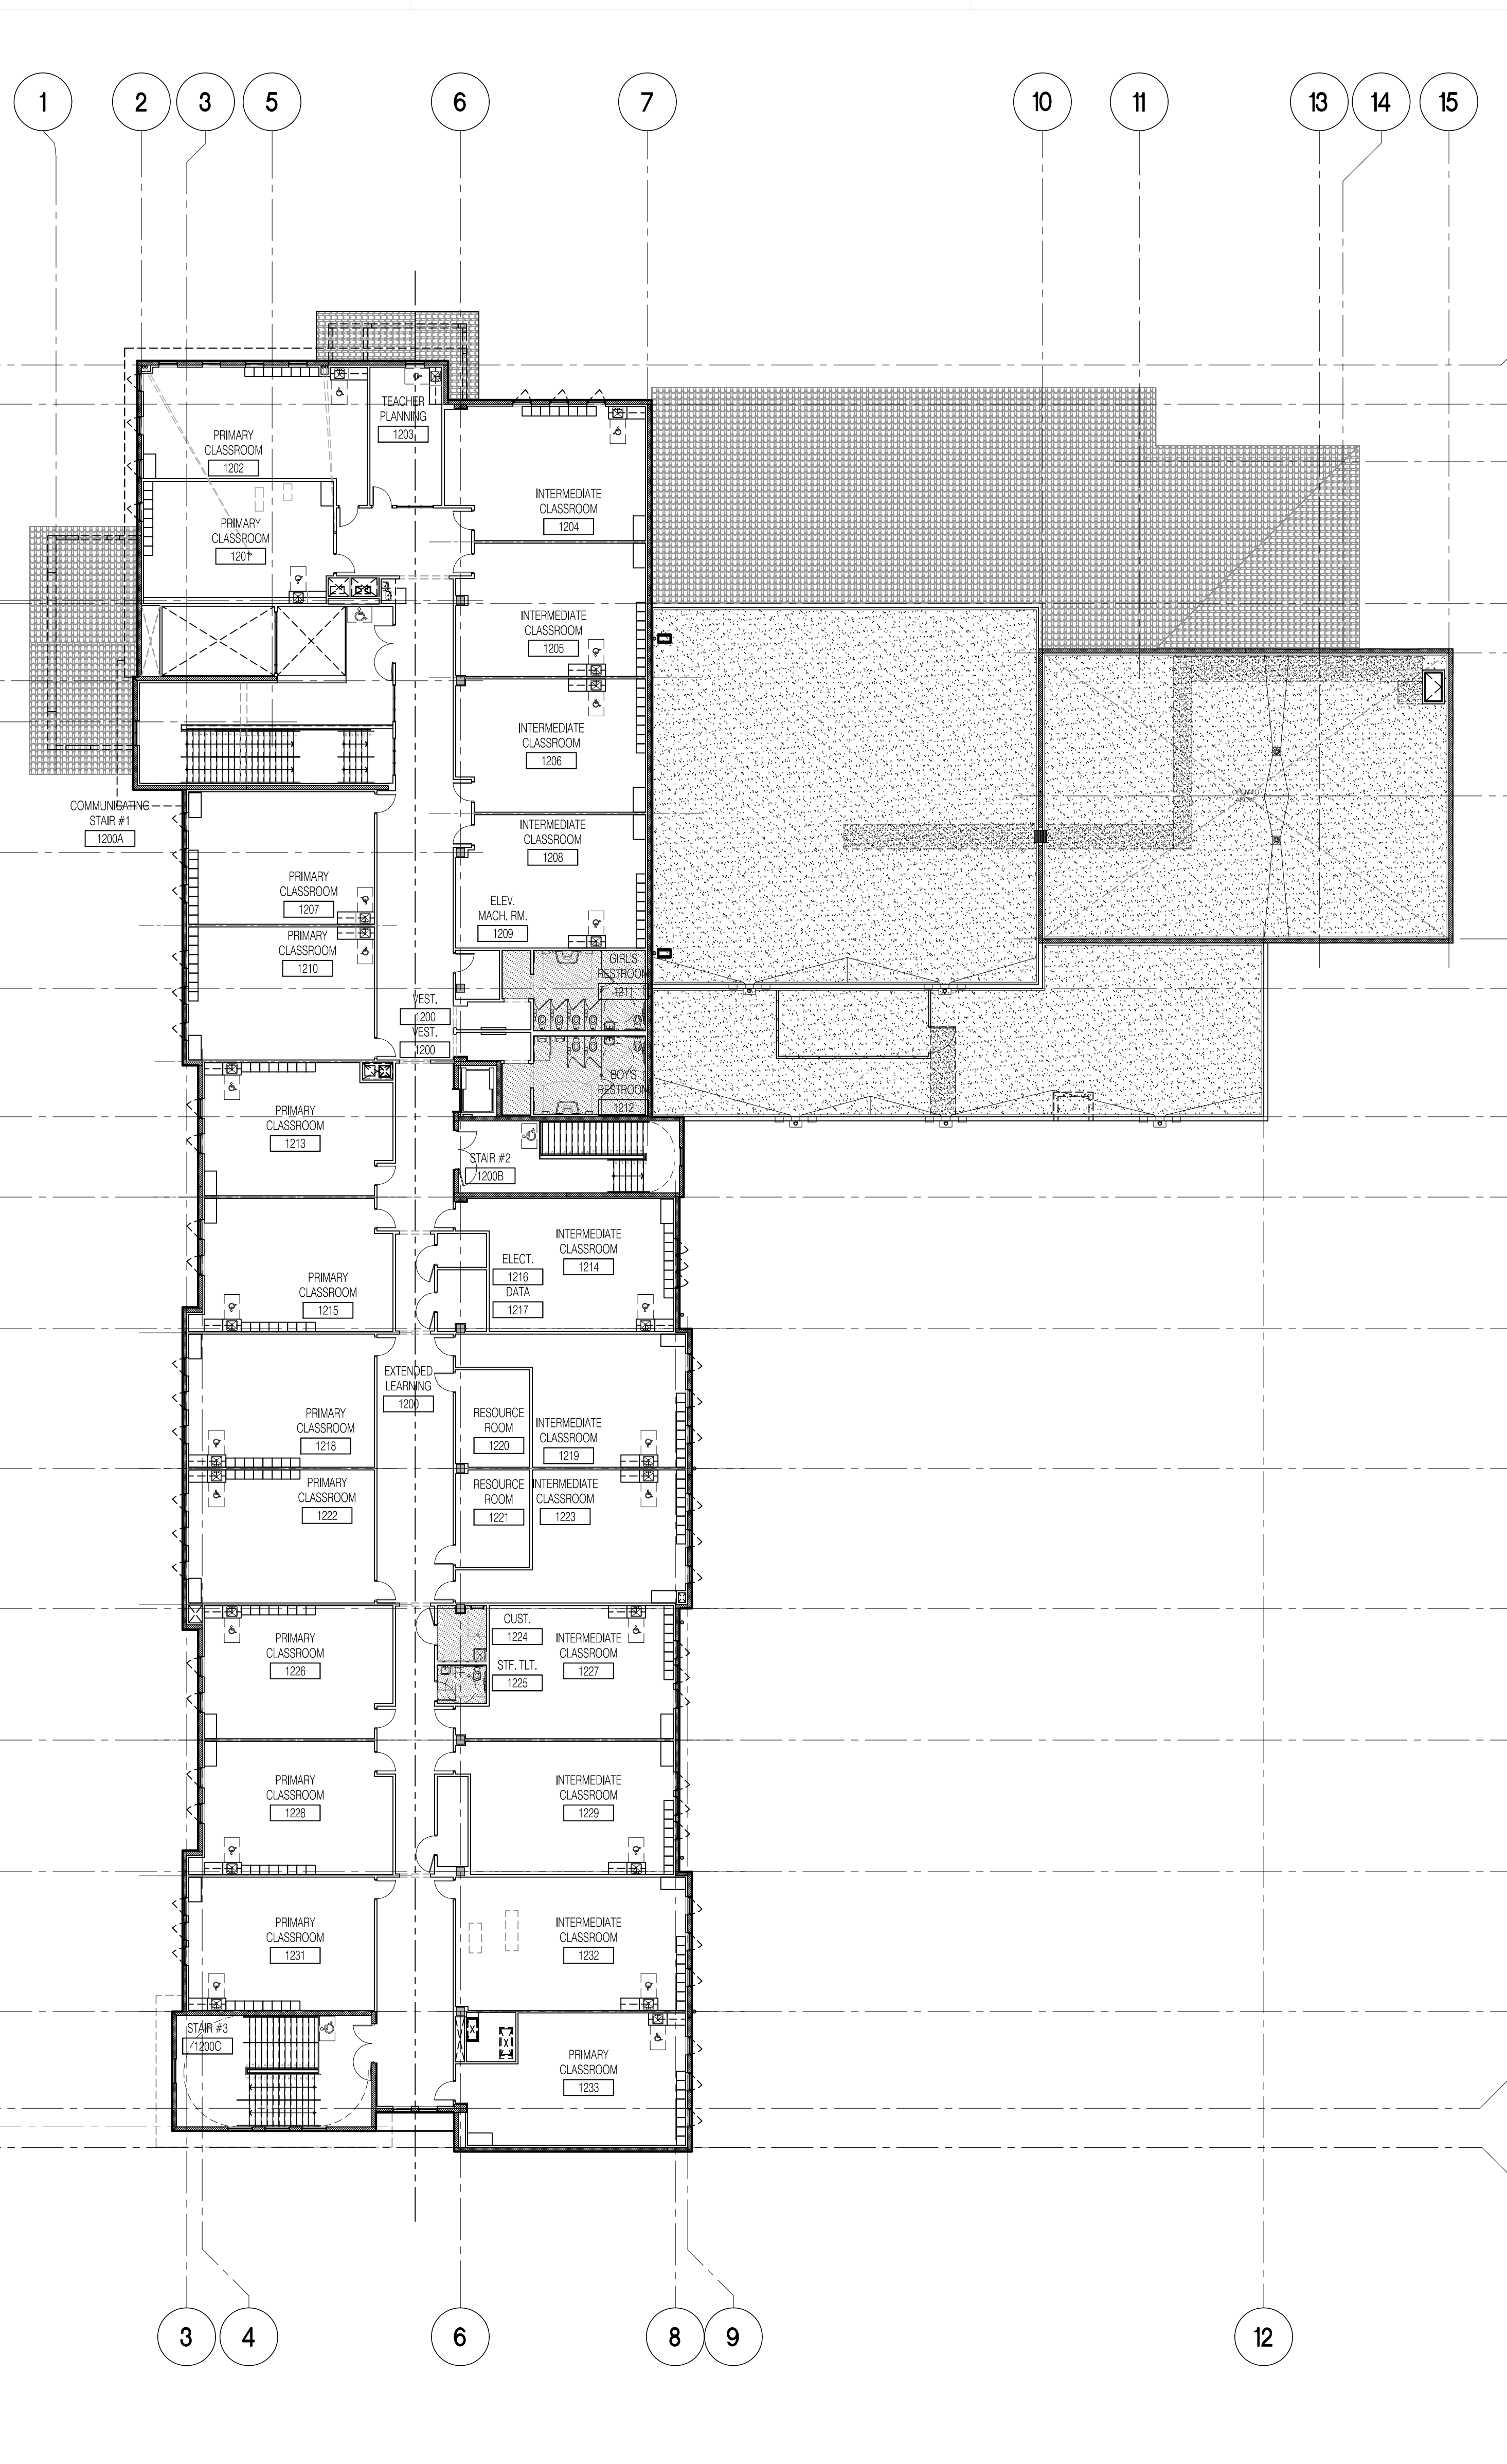

2 OVERALL SECOND FLOOR PLAN
Scale: 1/16" = 1'-0"

FLOOR PLAN LEGEND

2" RECESS FOR PORCELAIN/QUARRY TILE	NEW CONCRETE MASONRY WALL
6" RECESS WALK-IN FREEZER AND COOLER	NEW CONCRETE MASONRY WALL WITH BRICK/STONE CLADDING
5/8" RECESS FOR ENTRY DOOR MAT	NEW DRYWALL STUD PARTITION WALL
EXISTING BUILT STRUCTURE WORK NOT IN SCOPE	NEW CONCRETE
----- PROJECT LIMIT LINE	

Section A-XXX	Elevation X/A-XXX	Sheet X/A-XXX
Building Section Tag	Exterior Elevation Tag	Interior Elevation Tag
WALL SECTION TAG	DOOR NUMBER TAG	WINDOW TYPE TAG
Partition Type	LOUVER TYPE TAG	STOREFRONT TAG
Column Grid		

Room Name Top
Room Name Bot
Room Number
Program SF/Actual SF
Student Stations
Life Safety SF
Life Safety SF/Occupants
Life Safety Occupants
Ceiling Height

REVISION NAME:
Date
REVISION TAG

- ### FLOOR PLAN GENERAL NOTES
- BEFORE INSTALLATION, CONTRACTOR SHALL COORDINATE WITH THE ARCHITECT THE EXACT MOUNTING LOCATIONS OF ALL SWITCHES, WALL RECEPTACLES, PLUGS, THERMOSTATS AND OTHER WALL MOUNTED FIXTURES.
 - REFER TO ENLARGED FLOOR PLANS DRAWINGS (A-700-752) FOR F.F.&E.
 - DIMENSIONS ARE TYPICALLY SHOWN FROM OUTSIDE FACE OF CMU WALL TO OUTSIDE FACE OF CMU WALL, OR CENTERLINE OF PARTITION, UNLESS NOTED OTHERWISE. CONTRACTOR SHALL NOTE SPECIAL LOCATIONS IN WHICH "CLEAR" DIMENSION IS SPECIFIED. THIS IS A DIMENSION FROM FINISH TO FINISH.
 - ALL WALLS WITHIN PROJECT LIMIT WHICH ARE DAMAGED ARE TO BE PATCHED WHERE DAMAGE OCCURS TO MATCH EXISTING ADJACENT FINISH. ALL WALLS TO HAVE CONTINUOUS SMOOTH FINISH. ALL WALLS TO BE REPAINTED AT RENOVATED AREAS (IF APPLICABLE).
 - ALL EXPOSED AREAS AT OCCUPIED AREAS ARE TO BE FULLY PAINTED INCLUDING COLOR CODING OF ALL SYSTEMS.
 - CONTRACTOR TO COORDINATE LOCATION OF ALL TEMPORARY DUST AND PROTECTION BARRIERS TO MAINTAIN SAFE ACCESS TO EGRESS AT ALL TIMES (BUILDING AND SITE). CONSTRUCTION IQ MANAGEMENT PLAN SHALL BE POSTED AT ALL TIMES.
 - CONTRACTOR TO MAINTAIN ALL PROTECTED WALL ASSEMBLIES AND OPENING RATINGS.
 - CONTRACTOR TO VERIFY CONDITION OF FLOOR SLAB PRIOR TO FINISHING (PATCH, REPAIR AND SEAL IF NEEDED). PREPARE ALL AREAS PER MANUFACTURER'S REQUIREMENTS TO RECEIVE NEW FINISHES.
 - CONTRACTOR TO COORDINATE ALL 2ND FLOOR PERFORATIONS TO AVOID STRUCTURE BELOW.
 - ALL SLAB RECESSES ARE TO BE COORDINATED AND CONFIRMED PRIOR TO CONSTRUCTION OF FLOOR SLAB.
 - CONTRACTOR TO PROVIDE ADHERED INSULATION AT UNDERSIDE AND TOP OF ALL EXTERIOR SLAB AREAS TO CLOSE BUILDING ENVELOPE (I.E. ABOVE EXTERIOR DOORS AND BELOW SLAB AT EXTERIOR AREA ABOVE CORRIDOR/ENTRY AREAS OF THE BUILDING).
 - SLOPE ALL FLOORS TO DRAIN. PROVIDE SLAB RECESS (2") AS NOTED AT ALL AREAS TO RECEIVE FLOOR DRAIN.
 - PROVIDE SLOPE TO DRAIN AT ALL MECHANICAL ROOM FLOORS PRIOR TO INSTALLATION OF SERVICE PAD. PROVIDE WATERPROOFING PEDESTRIAN MEMBRANE AT ALL ELEVATED MECHANICAL ROOMS AND WET AREAS.
 - PROVIDE ANTI-FRACTURE AND WATERPROOFING MEMBRANE AT ALL TOILET AND SHOWER (INDIVIDUAL AND GROUP) ROOMS ABOVE THE GROUND FLOOR. PROVIDE SHOWER PAN AND FLASHING FOR ALL SHOWER ENCLOSURES (AS APPLICABLE).
 - CONTRACTOR TO COORDINATE WITH REQUIRED PENETRATIONS, FINISH PLANS AND LIFE SAFETY DRAWINGS FOR ALL WALL TYPES AND PARTITION CONSTRUCTION.
 - REFER TO ENLARGED FLOOR PLANS DRAWINGS (A-700'S) FOR TOILET ROOM AND RESTROOM DIMENSIONS.


CHECKED BY: LR. DRAWN BY: CV.

CONSULTANT INFO:



NEW ELEMENTARY SCHOOL (K-5)
VENETIAN PARC WEST
SOUTHWEST 157th AVENUE and 174th STREET
MIAMI, FL. 33187
MDCPS PROJECT No. 01892600


KEY PLAN

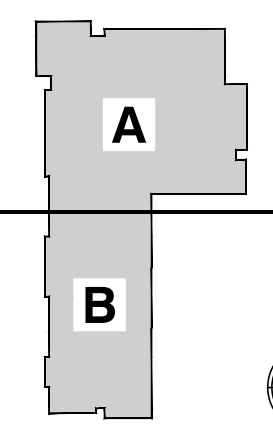

CONSULTANT INFO:


DESIGN & CONSTRUCTION TEAM

RODRIGUEZ ARCHITECTS INCORPORATED
2121 PONCE DE LEON BLVD. STE. 1010
CORAL GABLES, FL. 33134
TEL: (305) 448-3373
FAX: (305) 448-3374
AAC - 001933

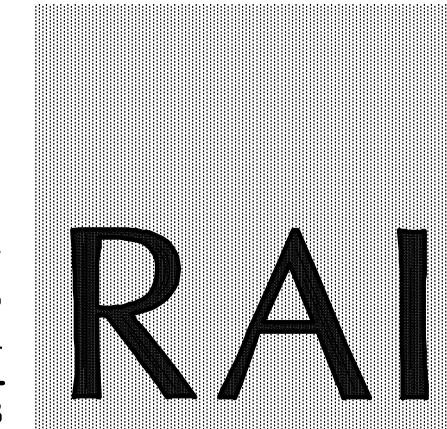

REVISIONS:

DRAWING TITLE:
OVERALL FIRST AND SECOND FLOOR PLANS
SCALE AS NOTED
ISSUE DATE: 12/16/19
PROJECT NO: 1906
SHEET: **A-200**

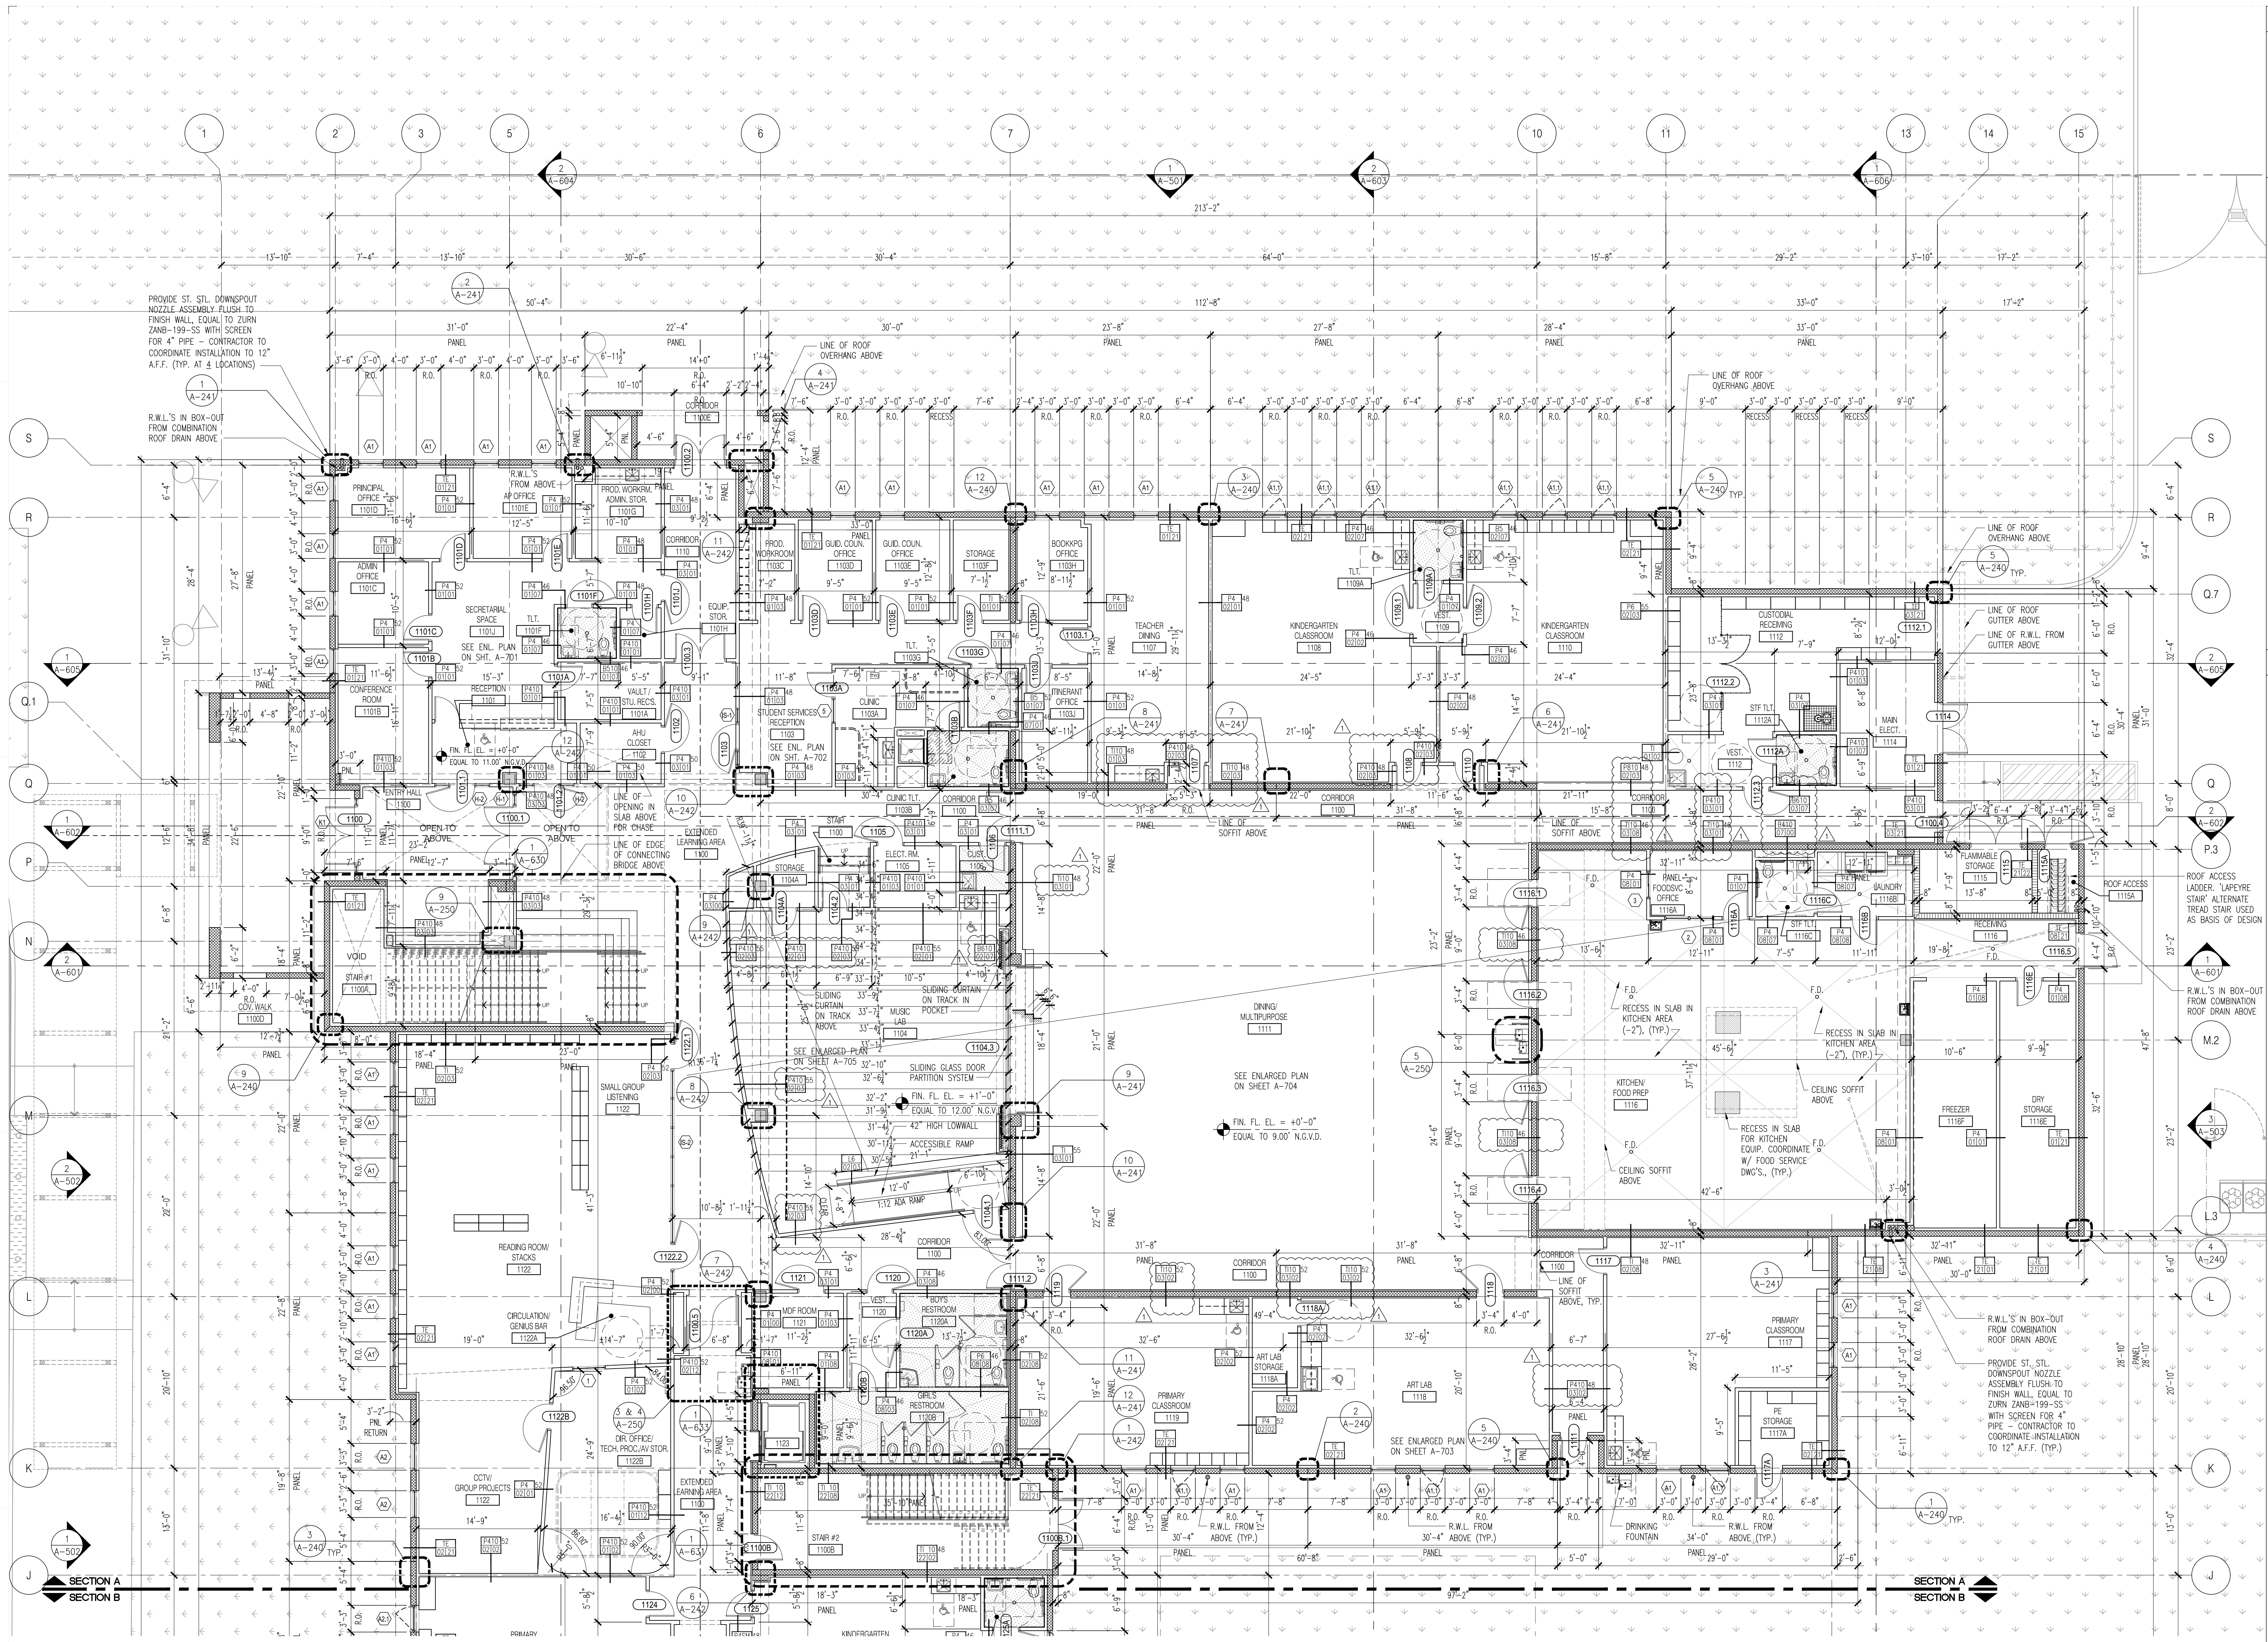

FLOOR PLAN LEGEND

2" RECESS FOR PORCELAIN/QUARRY TILE

6" RECESS @ WALK-IN FREEZER AND COOLER

5/8" RECESS FOR ENTRY DOOR MAT

EXISTING BUILT STRUCTURE WORK NOT IN SCOPE

PROJECT LIMIT LINE

NEW CONCRETE MASONRY WALL

NEW CONCRETE MASONRY WALL WITH BRICK/STONE CLADDING

NEW DRYWALL STUD PARTITION WALL

NEW CONCRETE

Section

Sheet

BUILDING SECTION TAG

WALL SECTION TAG

Partition Type

STC

COLUMN GRID

Room Name Top

Room Name Bot

Room Number

Program SF/Actual SF

Student Stations

Life Safety SF

Life Safety SF/Occupants

Life Safety Occupants

Ceiling Height

Room ID Tag

REVISION NAME:

Date

Revision Tag

Sheet

Exterior Elevation Tag

Interior Elevation Tag

Door Number Tag

Window Type Tag

Louver Type Tag

Storefront Tag

First Floor Location

1.0 Slab Elevation

0'-0" = 1/8" N.E.D.

Elevation

RTOP

Room Name Top

Room Number

Program SF/Actual SF

Student Stations

Life Safety SF

Life Safety SF/Occupants

Life Safety Occupants

Ceiling Height

Room ID Tag

REVISION NAME:

Date

Revision Tag

FLOOR PLAN GENERAL NOTES

1. BEFORE INSTALLATION, CONTRACTOR SHALL COORDINATE WITH THE ARCHITECT THE EXACT MOUNTING LOCATIONS OF ALL SWITCHES, WALL RECEPTACLES, PLUGS, THERMOSTATS AND OTHER WALL MOUNTED FIXTURES.

2. REFER TO ENLARGED FLOOR PLANS DRAWINGS (A-700-752) FOR F.F.&E.

3. DIMENSIONS ARE TYPICALLY SHOWN FROM OUTSIDE FACE OF CMU WALL TO OUTSIDE FACE OF CMU WALL OR CENTERLINE OF PARTITION, UNLESS NOTED OTHERWISE. CONTRACTOR SHALL NOTE SPECIAL LOCATIONS IN WHICH "CLEAR" DIMENSION IS SPECIFIED. THIS IS A DIMENSION FROM FINISH TO FINISH.

4. ALL WALLS WITHIN PROJECT LIMIT WHICH ARE DAMAGED ARE TO BE PATCHED WHERE DAMAGE OCCURS TO MATCH EXISTING ADJACENT FINISH. ALL WALLS TO HAVE CONTINUOUS SMOOTH FINISH. ALL WALLS TO BE REPAINTED AT RENOVATED AREAS (IF APPLICABLE).

5. ALL EXPOSED AREAS AT OCCUPIED AREAS ARE TO BE FULLY PAINTED INCLUDING COLOR CODING OF ALL SYSTEMS.

6. CONTRACTOR TO COORDINATE LOCATION OF ALL TEMPORARY DUST AND PROTECTION BARRIERS TO MAINTAIN SAFE ACCESS TO EGRESS AT ALL TIMES (BUILDING AND SITE). CONSTRUCTION HQ MANAGEMENT PLAN SHALL BE POSTED AT ALL TIMES.

7. CONTRACTOR TO MAINTAIN ALL PROTECTED WALL ASSEMBLIES AND OPENING RATINGS.

8. CONTRACTOR TO VERIFY CONDITION OF FLOOR SLAB PRIOR TO FINISHING (PATCH, REPAIR AND SEAL IF NEEDED). PREPARE ALL AREAS PER MANUFACTURER'S REQUIREMENTS TO RECEIVE NEW FINISHES.

9. CONTRACTOR TO COORDINATE ALL 2ND FLOOR PERFORATIONS TO AVOID STRUCTURE BELOW.

10. ALL SLAB RECESSES ARE TO BE COORDINATED AND CONFIRMED PRIOR TO CONSTRUCTION OF FLOOR SLAB.

11. CONTRACTOR TO PROVIDE ADHERED INSULATION AT UNDERSIDE AND TOP OF ALL EXTERIOR SLAB AREAS TO CLOSE BUILDING ENVELOPE (I.E. ABOVE EXTERIOR DOORS AND BELOW SLAB AT EXTERIOR AREA ABOVE CORRIDOR/ENTRY AREAS OF THE BUILDING).

12. SLOPE ALL FLOORS TO DRAIN. PROVIDE SLAB RECESS (2") AS NOTED AT ALL AREAS TO RECEIVE FLOOR DRAIN.

13. PROVIDE SLOPE TO DRAIN AT ALL MECHANICAL ROOM FLOORS PRIOR TO INSTALLATION OF SERVICE PAD. PROVIDE WATERPROOFING PEDESTAL MEMBRANE AT ALL ELEVATED MECHANICAL ROOMS AND WET AREAS.

14. PROVIDE ANTI-FRACTURE AND WATERPROOFING MEMBRANE AT ALL TOILET AND SHOWER (INDIVIDUAL AND GROUP) ROOMS ABOVE THE GROUND FLOOR. PROVIDE SHOWER PAN AND FLASHING FOR ALL SHOWER ENCLOSURES (AS APPLICABLE).

15. CONTRACTOR TO COORDINATE WITH REQUIRED PENETRATIONS, FINISH PLANS AND LIFE SAFETY DRAWINGS FOR ALL WALL TYPES AND PARTITION CONSTRUCTION.

16. REFER TO ENLARGED FLOOR PLANS DRAWINGS (A-700'S) FOR TOILET ROOM AND RESTROOM DIMENSIONS.

1 ENLARGED FIRST FLOOR PLAN - AREA A
A-211 Scale: 1/8" = 1'-0"

CHECKED BY: LR

DRAWN BY: CV

CONSULTANT INFO

MIAMI-DADE COUNTY

giving our students the world

PUBLIC SCHOOLS

NEW ELEMENTARY SCHOOL (K-5)

VENETIAN PARC WEST

SOUTHWEST 157th AVENUE and 174th STREET

MIAMI, FL 33187

MDCPS PROJECT No. 01892600

KEY PLAN

A

B

CONSULTANT INFO

RODRIGUEZ ARCHITECTS INCORPORATED

2121 PONCE DE LEON BLVD. STE 1010

CORAL GABLES, FL 33134

TEL: (305) 448-3373

FAX: (305) 448-3374

AAC - 001933

REVISIONS:

02.14.2020

BUILDING DEPARTMENT COMMENTS

DRAWING TITLE:

ENLARGED FIRST FLOOR PLAN AREA A

SCALE AS NOTED

ISSUE DATE: 12.16.19

PROJECT NO: 1906

SHEET: A-211



DRAWING TITLE:


**ENLARGED
FIRST FLOOR PLAN
AREA B**

SCALE AS NOTED

ISSUE DATE: 12.16.19	PROJECT NO. 1906
--------------------------------	----------------------------

SHEET:

A-212

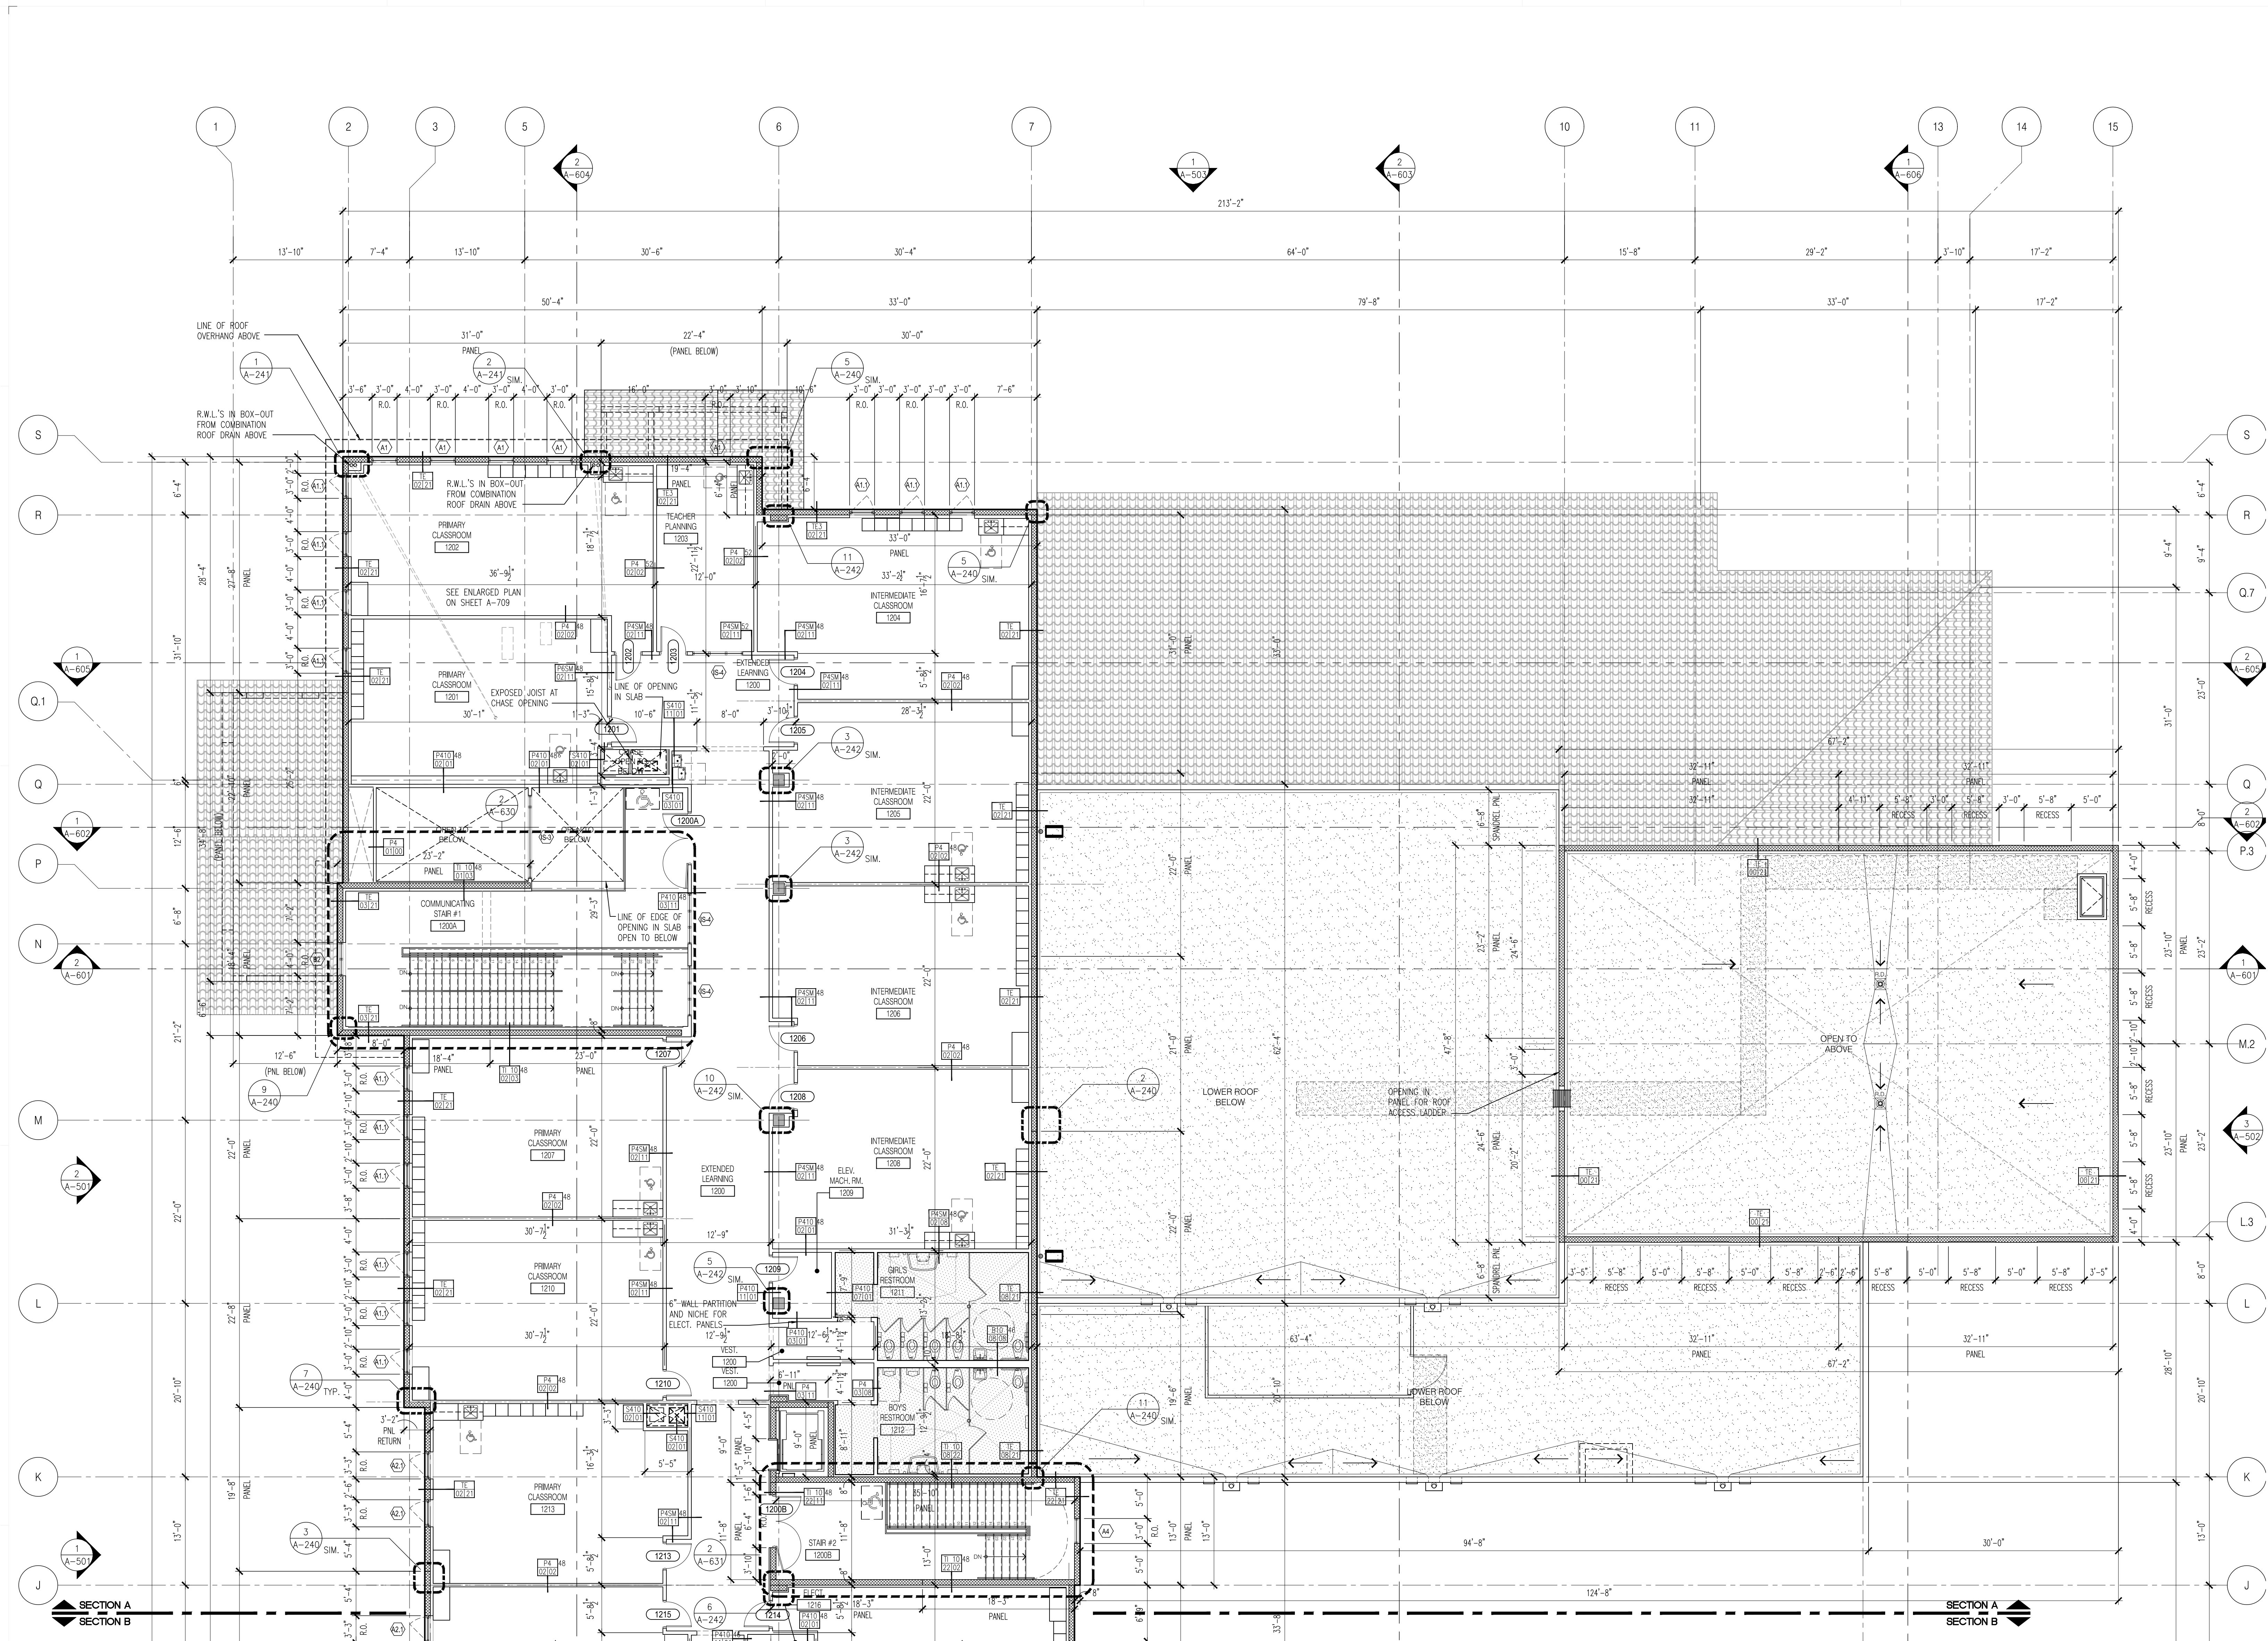

FLOOR PLAN LEGEND

	2" RECESS FOR PORCELAIN/QUARRY TILE		NEW CONCRETE MASONRY WALL WITH BRICK/STONE CLADDING
	6" RECESS WALK-IN FREEZER AND COOLER		NEW DRYWALL STUD PARTITION WALL
	5/8" RECESS FOR ENTRY DOOR MAT		NEW CONCRETE
	EXISTING BUILT STRUCTURE WORK NOT IN SCOPE		
	PROJECT LIMIT LINE		

Section
A-XXX
Sheet
X/A-XXX

Elevation
X/A-XXX
Sheet
X/A-XXX

Rating
X/A-XXX
Sheet
X/A-XXX

Partition Type
X/A-XXX
Sheet
X/A-XXX

Column Grid
X/A-XXX
Sheet
X/A-XXX

First Floor
X/A-XXX
Sheet
X/A-XXX

Room ID Tag
X/A-XXX
Sheet
X/A-XXX

Room Name
X/A-XXX
Sheet
X/A-XXX

Room Number
X/A-XXX
Sheet
X/A-XXX

Program SF/Actual SF
X/A-XXX
Sheet
X/A-XXX

Student Stations
X/A-XXX
Sheet
X/A-XXX

Life Safety SF
X/A-XXX
Sheet
X/A-XXX

Life Safety SF/Occupants
X/A-XXX
Sheet
X/A-XXX

Life Safety Occupants
X/A-XXX
Sheet
X/A-XXX

Life Safety Ceiling Height
X/A-XXX
Sheet
X/A-XXX

REVISION NAME
X/A-XXX
Sheet
X/A-XXX

REVISION TAG
X/A-XXX
Sheet
X/A-XXX

- FLOOR PLAN GENERAL NOTES**
- BEFORE INSTALLATION, CONTRACTOR SHALL COORDINATE WITH THE ARCHITECT THE EXACT MOUNTING LOCATIONS OF ALL SWITCHES, WALL RECEPTACLES, PLUGS, THERMOSTATS AND OTHER WALL MOUNTED FIXTURES.
 - REFER TO ENLARGED FLOOR PLANS DRAWINGS (A-700-752) FOR F.F. & E.
 - DIMENSIONS ARE TYPICALLY SHOWN FROM OUTSIDE FACE OF CMU WALL TO OUTSIDE FACE OF CMU WALL, OR CENTERLINE OF PARTITION, UNLESS NOTED OTHERWISE. CONTRACTOR SHALL NOTE SPECIAL LOCATIONS IN WHICH "CLEAR" DIMENSION IS SPECIFIED. THIS IS A DIMENSION FROM FINISH TO FINISH.
 - ALL WALLS WITHIN PROJECT LIMIT WHICH ARE DAMAGED ARE TO BE PATCHED WHERE DAMAGE OCCURS TO MATCH EXISTING ADJACENT FINISH. ALL WALLS TO HAVE CONTINUOUS SMOOTH FINISH. ALL WALLS TO BE REPAINTED AT RENOVATED AREAS (IF APPLICABLE).
 - ALL EXPOSED AREAS AT OCCUPIED AREAS ARE TO BE FULLY PAINTED INCLUDING COLOR CODING OF ALL SYSTEMS.
 - CONTRACTOR TO COORDINATE LOCATION OF ALL TEMPORARY DUST AND PROTECTION BARRIERS TO MAINTAIN SAFE ACCESS TO EGRESS AT ALL TIMES (BUILDING AND SITE). CONSTRUCTION HQ MANAGEMENT PLAN SHALL BE POSTED AT ALL TIMES.
 - CONTRACTOR TO MAINTAIN ALL PROTECTED WALL ASSEMBLIES AND OPENING RATINGS.
 - CONTRACTOR TO VERIFY CONDITION OF FLOOR SLAB PRIOR TO FINISHING (PATCH, REPAIR AND SEAL IF NEEDED). PREPARE ALL AREAS PER MANUFACTURER'S REQUIREMENTS TO RECEIVE NEW FINISHES.
 - CONTRACTOR TO COORDINATE ALL 2ND FLOOR PERFORATIONS TO AVOID STRUCTURE BELOW.
 - ALL SLAB RECESSES ARE TO BE COORDINATED AND CONFIRMED PRIOR TO CONSTRUCTION OF FLOOR SLAB.
 - CONTRACTOR TO PROVIDE ADHERED INSULATION AT UNDERSIDE AND TOP OF ALL EXTERIOR SLAB AREAS TO CLOSE BUILDING ENVELOPE (I.E. ABOVE EXTERIOR DOORS AND BELOW SLAB AT EXTERIOR AREA ABOVE CORRIDOR/ENTRY AREAS OF THE BUILDING).
 - SLOPE ALL FLOORS TO DRAIN. PROVIDE SLAB RECESS (2") AS NOTED AT ALL AREAS TO RECEIVE FLOOR DRAIN.
 - PROVIDE SLOPE TO DRAIN AT ALL MECHANICAL ROOM FLOORS PRIOR TO INSTALLATION OF SERVICE PAD. PROVIDE WATERPROOFING PEDESTRIAN MEMBRANE AT ALL ELEVATED MECHANICAL ROOMS AND WET AREAS.
 - PROVIDE ANTI-FRACTURE AND WATERPROOFING MEMBRANE AT ALL TOILET AND SHOWER (INDIVIDUAL AND GROUP) ROOMS ABOVE THE GROUND FLOOR. PROVIDE SHOWER PAN AND FLASHING FOR ALL SHOWER ENCLOSURES (AS APPLICABLE).
 - CONTRACTOR TO COORDINATE WITH REQUIRED PENETRATIONS, FINISH PLANS AND LIFE SAFETY DRAWINGS FOR ALL WALL TYPES AND PARTITION CONSTRUCTION.
 - REFER TO ENLARGED FLOOR PLANS DRAWINGS (A-700'S) FOR TOILET ROOM AND RESTROOM DIMENSIONS.

1 ENLARGED SECOND FLOOR PLAN - AREA A
A-221 Scale: 1/8" = 1'-0"

CHECKED BY: LR. DRAWN BY: C.V.

CONSULTANT INFO:

NEW ELEMENTARY SCHOOL (K-5)
VENETIAN PARC WEST
SOUTHWEST 157th AVENUE and 174th STREET
MIAMI, FL. 33187
MDCPS PROJECT No. 01892600

KEY PLAN

CONSULTANT INFO:

RODRIGUEZ ARCHITECTS INCORPORATED
2121 PONCE DE LEON BLVD. STE. 1010
CORAL GABLES, FL. 33134
TEL: (305) 448-3373
FAX: (305) 448-3374
AAC - 001933

RAI

REVISIONS:

1	12/16/19	1906
---	----------	------


DRAWING TITLE:

ENLARGED SECOND FLOOR PLAN AREA A

SCALE AS NOTED

ISSUE DATE: 12/16/19 PROJECT NO: 1906

SHEET: A-221

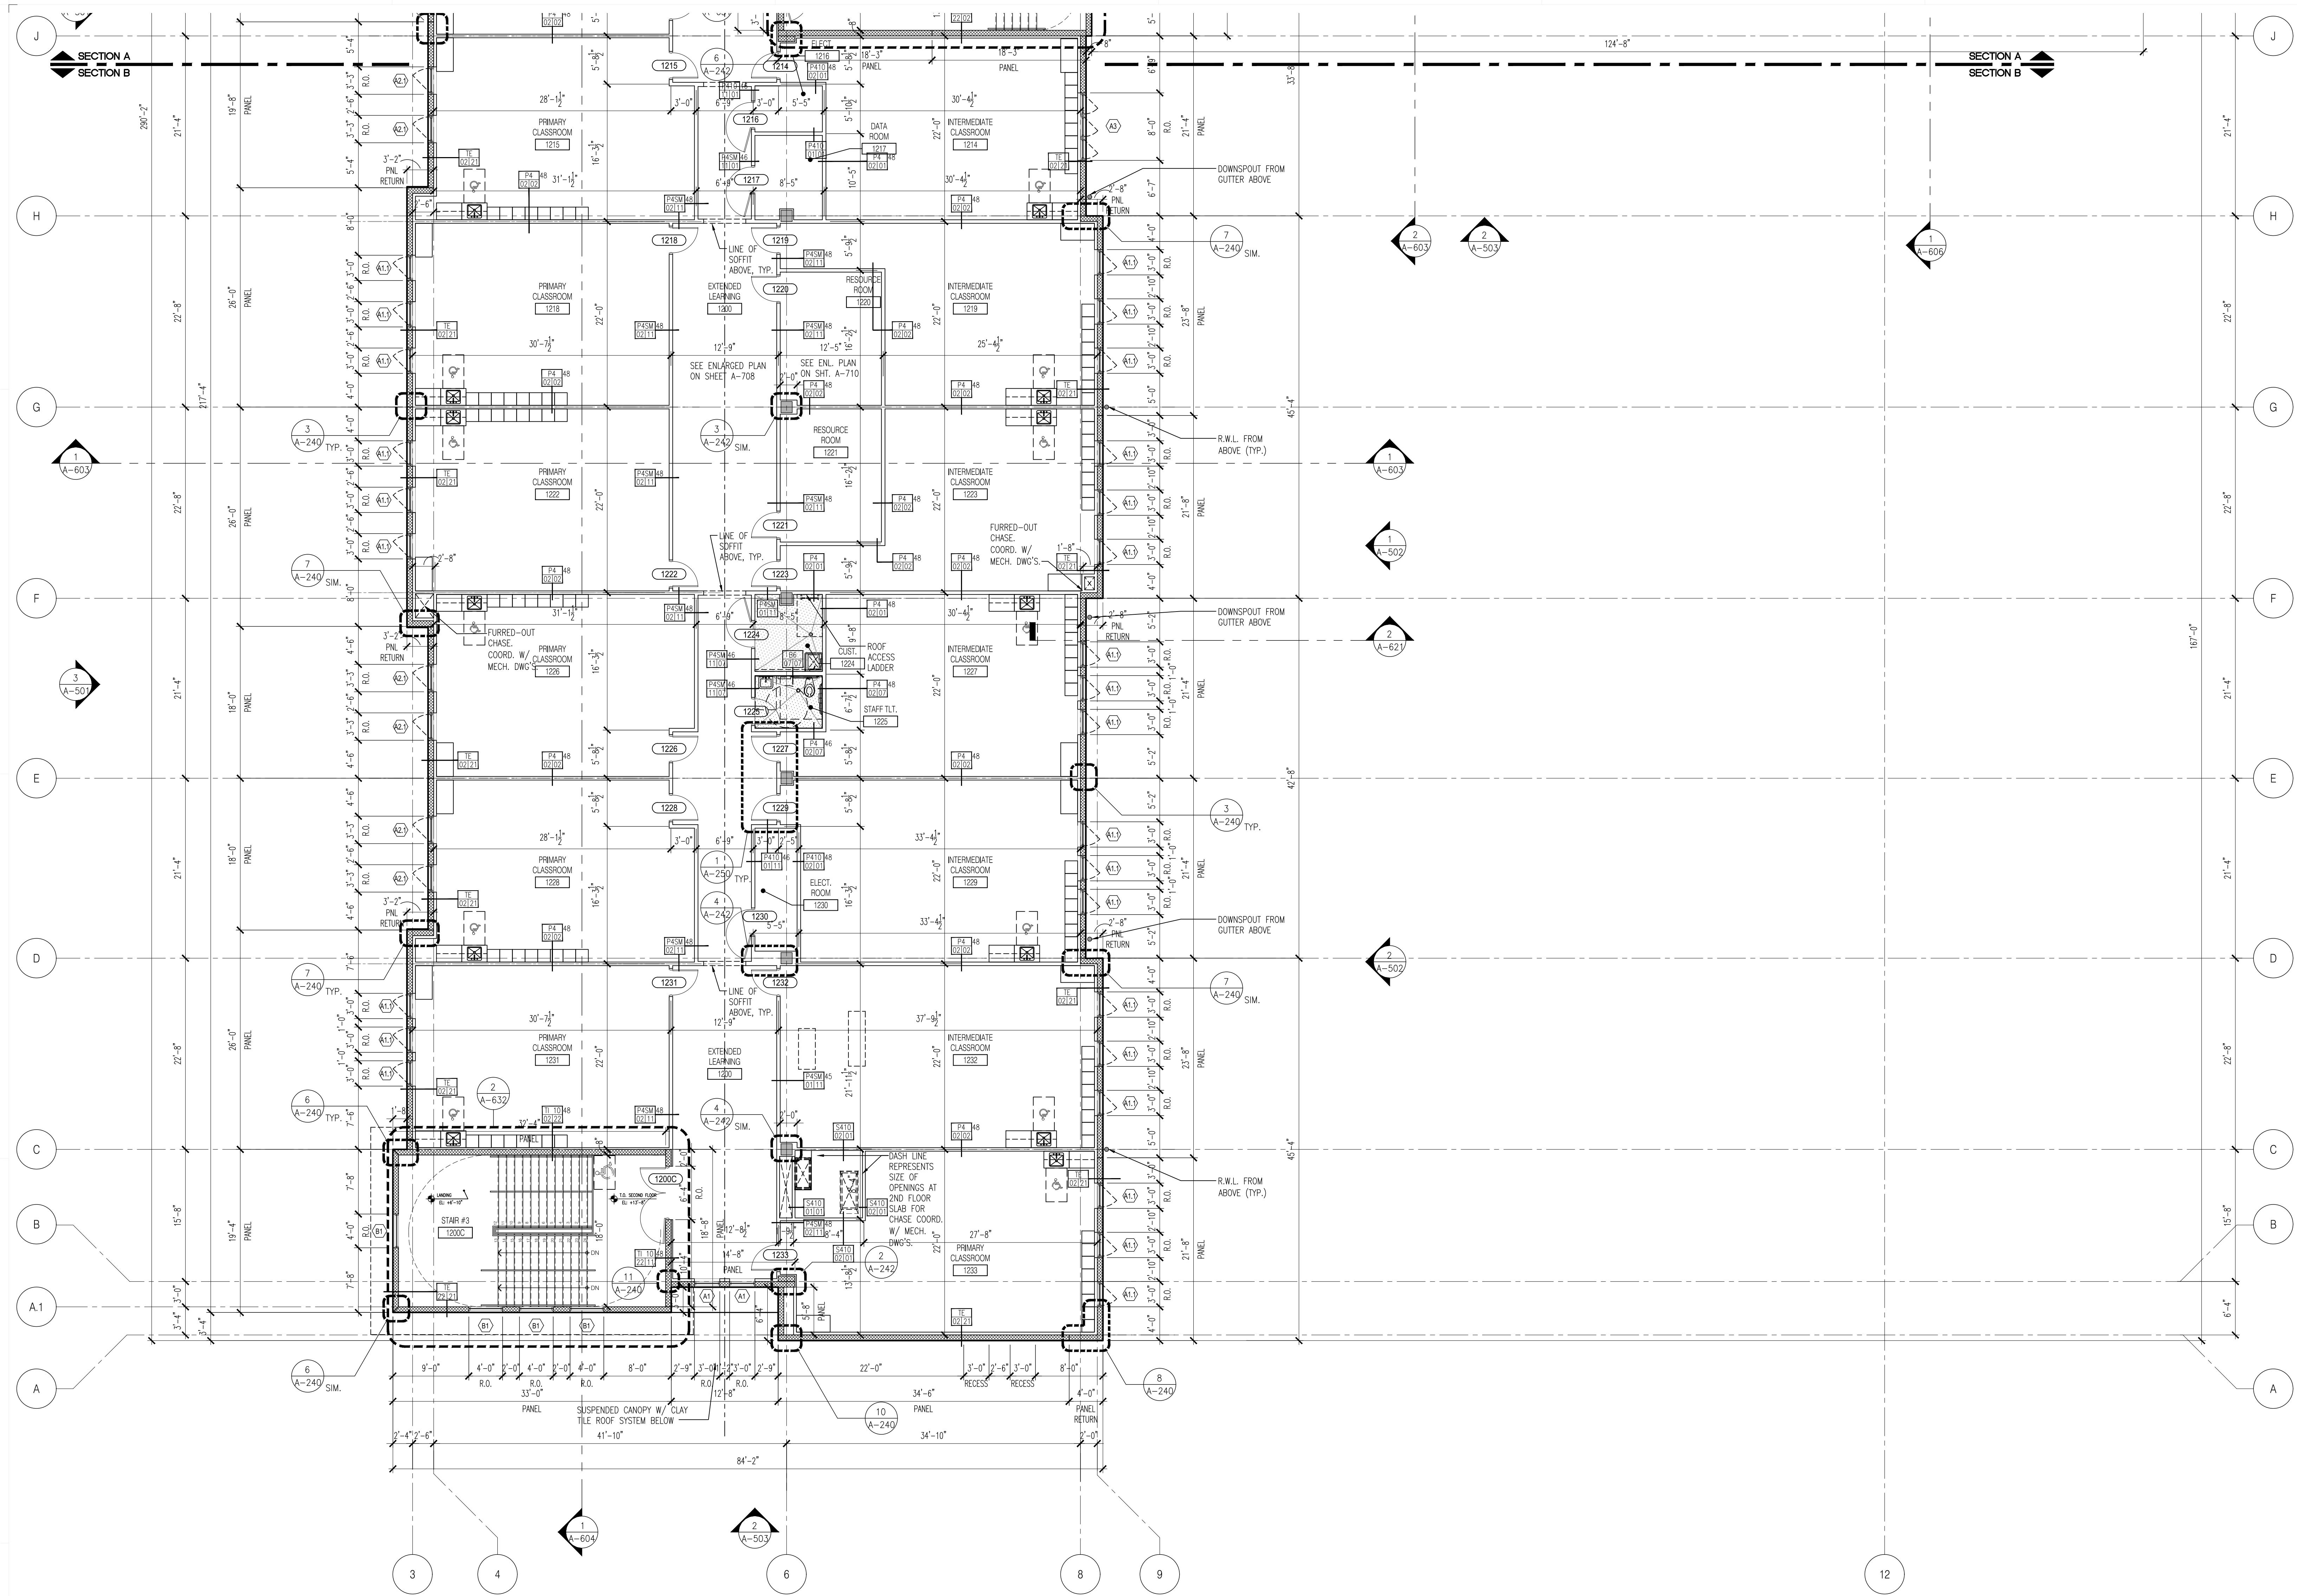

FLOOR PLAN LEGEND

	2" RECESS FOR PORCELAIN/QUARRY TILE		NEW CONCRETE MASONRY WALL
	6" RECESS FOR WALK-IN FREEZER AND COOLER		NEW CONCRETE MASONRY WALL WITH BRICK/STONE CLADDING
	5/8" RECESS FOR ENTRY DOOR MAT		NEW DRYWALL STUD PARTITION WALL
	EXISTING BUILT STRUCTURE WORK NOT IN SCOPE		NEW CONCRETE
	PROJECT LIMIT LINE		

	Section		Elevation		Sheet
	BUILDING SECTION TAG		EXTERIOR ELEVATION TAG		
	WALL SECTION TAG		INTERIOR ELEVATION TAG		
	PARTITION TYPE		DOOR NUMBER TAG		
	COLUMN GRID		WINDOW TYPE TAG		
			LOUVER TYPE TAG		
			STOREFRONT TAG		

FIRST FLOOR Floor Location
T.O. SLAB ELEVATION
0'-0" = 15'-0" N.G.V.D.


ELEVATION TAG

RTOP	Room Name Top
RBOT	Room Name Bot
RSUM	Room Number
PSF	Program SF/Actual SF
(PSF/OCCUPANT)	Student Stations
# OCCUPANTS	Life Safety SF
(#-0')	Life Safety SF/Occupants
	Life Safety Occupants
	Ceiling Height

ROOM ID TAG

REVISION NAME:
Date
REVISION TAG

- FLOOR PLAN GENERAL NOTES**
- BEFORE INSTALLATION, CONTRACTOR SHALL COORDINATE WITH THE ARCHITECT THE EXACT MOUNTING LOCATIONS OF ALL SWITCHES, WALL RECEPTACLES, PLUGS, THERMOSTATS AND OTHER WALL MOUNTED FIXTURES.
 - REFER TO ENLARGED FLOOR PLANS DRAWINGS (A-700-752) FOR F.P.&E.
 - DIMENSIONS ARE TYPICALLY SHOWN FROM OUTSIDE FACE OF CMU WALL TO OUTSIDE FACE OF CMU WALL, OR CENTERLINE OF PARTITION, UNLESS NOTED OTHERWISE CONTRACTOR SHALL NOTE SPECIAL LOCATIONS IN WHICH "CLEAR" DIMENSION IS SPECIFIED. THIS IS A DIMENSION FROM FINISH TO FINISH.
 - ALL WALLS WITHIN PROJECT LIMIT WHICH ARE DAMAGED ARE TO BE PATCHED WHERE DAMAGE OCCURS TO MATCH EXISTING ADJACENT FINISH. ALL WALLS TO HAVE CONTINUOUS SMOOTH FINISH. ALL WALLS TO BE REPAINTED AT RENOVATED AREAS (IF APPLICABLE).
 - ALL EXPOSED AREAS AT OCCUPIED AREAS ARE TO BE FULLY PAINTED INCLUDING COLOR CODING OF ALL SYSTEMS.
 - CONTRACTOR TO COORDINATE LOCATION OF ALL TEMPORARY DUST AND PROTECTION BARRIERS TO MAINTAIN SAFE ACCESS TO EGRESS AT ALL TIMES (BUILDING AND SITE). CONSTRUCTION IQD MANAGEMENT PLAN SHALL BE POSTED AT ALL TIMES.
 - CONTRACTOR TO MAINTAIN ALL PROTECTED WALL ASSEMBLIES AND OPENING RATINGS.
 - CONTRACTOR TO VERIFY CONDITION OF FLOOR SLAB PRIOR TO FINISHING (PATCH, REPAIR AND SEAL IF NEEDED). PREPARE ALL AREAS PER MANUFACTURER'S REQUIREMENTS TO RECEIVE NEW FINISHES.
 - CONTRACTOR TO COORDINATE ALL 2ND FLOOR PERFORATIONS TO AVOID STRUCTURE BELOW.
 - ALL SLAB RECESSES ARE TO BE COORDINATED AND CONFIRMED PRIOR TO CONSTRUCTION OF FLOOR SLAB.
 - CONTRACTOR TO PROVIDE ADHERED INSULATION AT UNDERSIDE AND TOP OF ALL EXTERIOR SLAB AREAS TO CLOSE BUILDING ENVELOPE (I.E. ABOVE EXTERIOR DOORS AND BELOW SLAB AT EXTERIOR AREA ABOVE CORRIDOR/ENTRY AREAS OF THE BUILDING).
 - SLOPE ALL FLOORS TO DRAIN. PROVIDE SLAB RECESS (2") AS NOTED AT ALL AREAS TO RECEIVE FLOOR DRAIN.
 - PROVIDE SLOPE TO DRAIN AT ALL MECHANICAL ROOM FLOORS PRIOR TO INSTALLATION OF SERVICE PAD. PROVIDE WATERPROOFING PEDESTRIAN MEMBRANE AT ALL ELEVATED MECHANICAL ROOMS AND WET AREAS.
 - PROVIDE ANTI-FRACTURE AND WATERPROOFING MEMBRANE AT ALL TOILET AND SHOWER (INDIVIDUAL AND GROUP) ROOMS ABOVE THE GROUND FLOOR. PROVIDE SHOWER PAN AND FLASHING FOR ALL SHOWER ENCLOSURES (AS APPLICABLE).
 - CONTRACTOR TO COORDINATE WITH REQUIRED PENETRATIONS, FINISH PLANS AND LIFE SAFETY DRAWINGS FOR ALL WALL TYPES AND PARTITION CONSTRUCTION.
 - REFER TO ENLARGED FLOOR PLANS DRAWINGS (A-700'S) FOR TOILET ROOM AND RESTROOM DIMENSIONS.

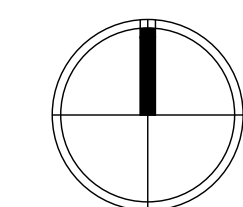


1 ENLARGED SECOND FLOOR PLAN - AREA B
A-222 Scale: 1/8" = 1'-0"

CHECKED BY: LR	DRAWN BY: CV
-------------------	-----------------

CONSULTANT INFO:

MIAMI-DADE COUNTY
giving our students the world
PUBLIC SCHOOLS

NEW ELEMENTARY SCHOOL (K-5)
VENETIAN PARC WEST
SOUTHWEST 157th AVENUE and 174th STREET
MIAMI, FL. 33187
MDCPS PROJECT No. 01892600

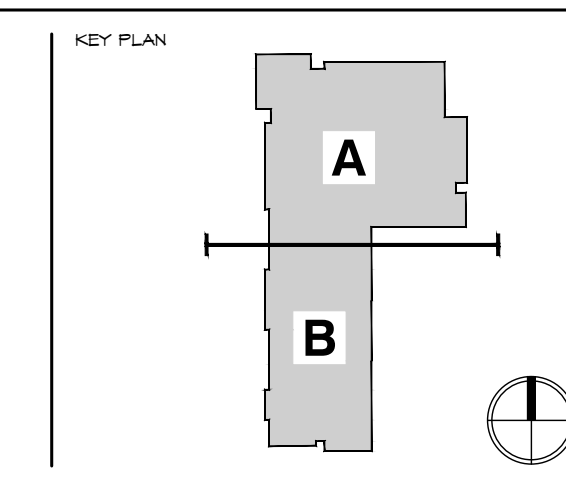

CONSULTANT INFO:

RODRIGUEZ ARCHITECTS INCORPORATED
2121 PONCE DE LEON BLVD. STE. 1010
CORAL GABLES, FL. 33134
TEL: (305) 448-3373
FAX: (305) 448-3374
A A C — 0 0 1 9 3 3

REVISIONS:













DATE	BY	DESCRIPTION
12/16/19	RAI	100%













DRAWING TITLE:

ENLARGED SECOND FLOOR PLAN AREA B

SCALE AS NOTED

ISSUE DATE: 12/16/19
PROJECT NO: 1906
SHEET: A-222

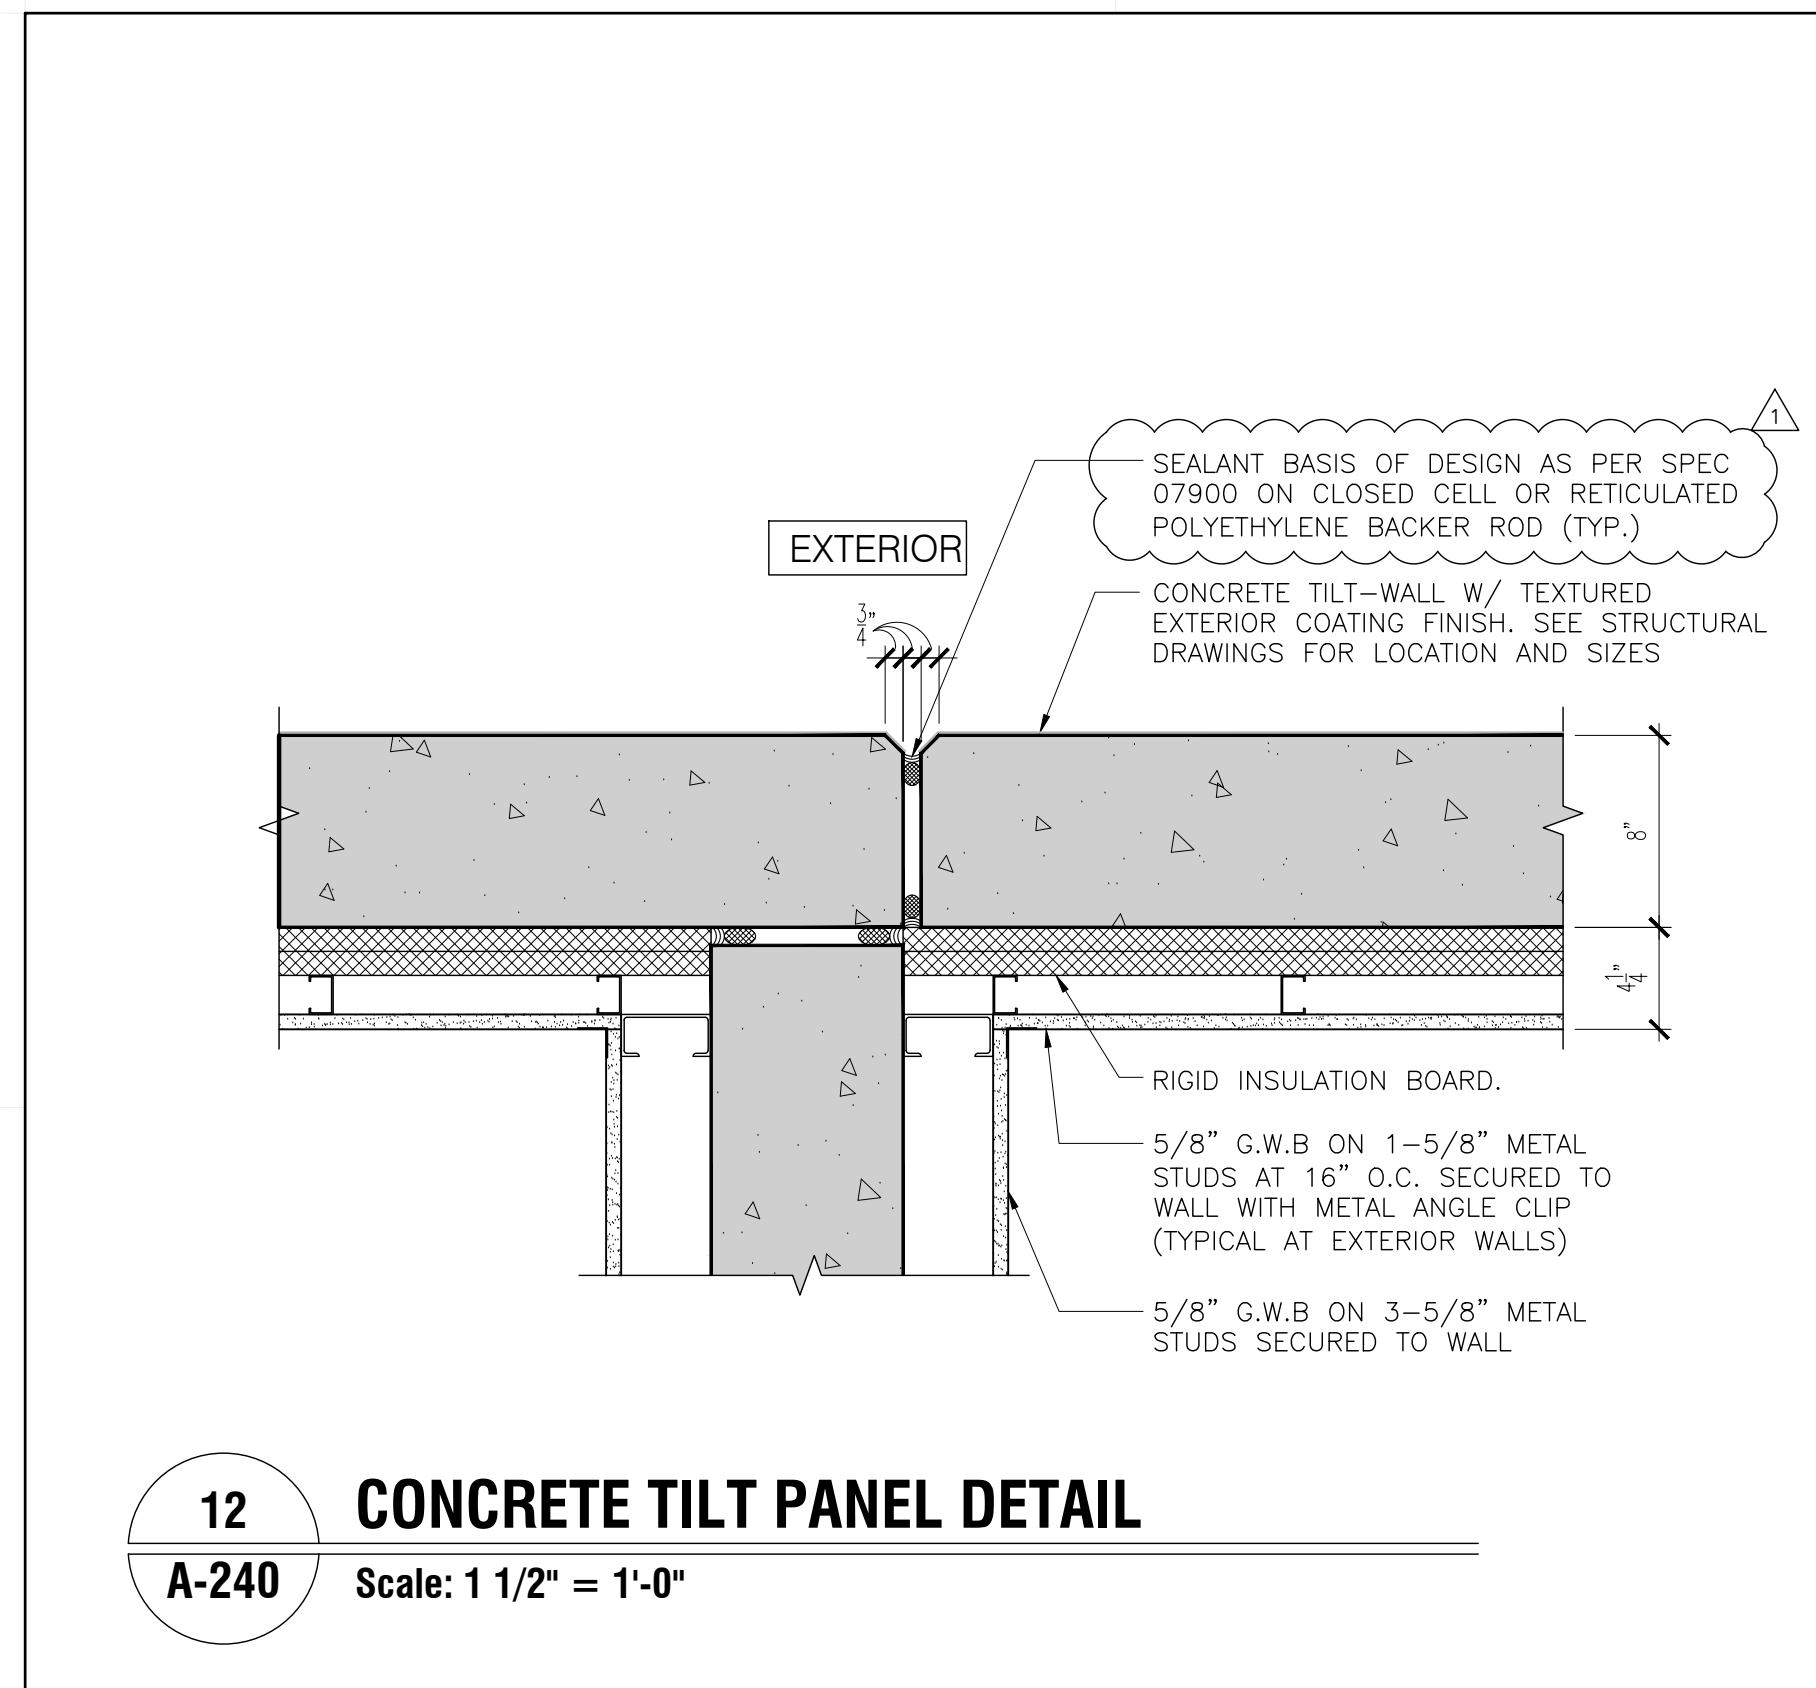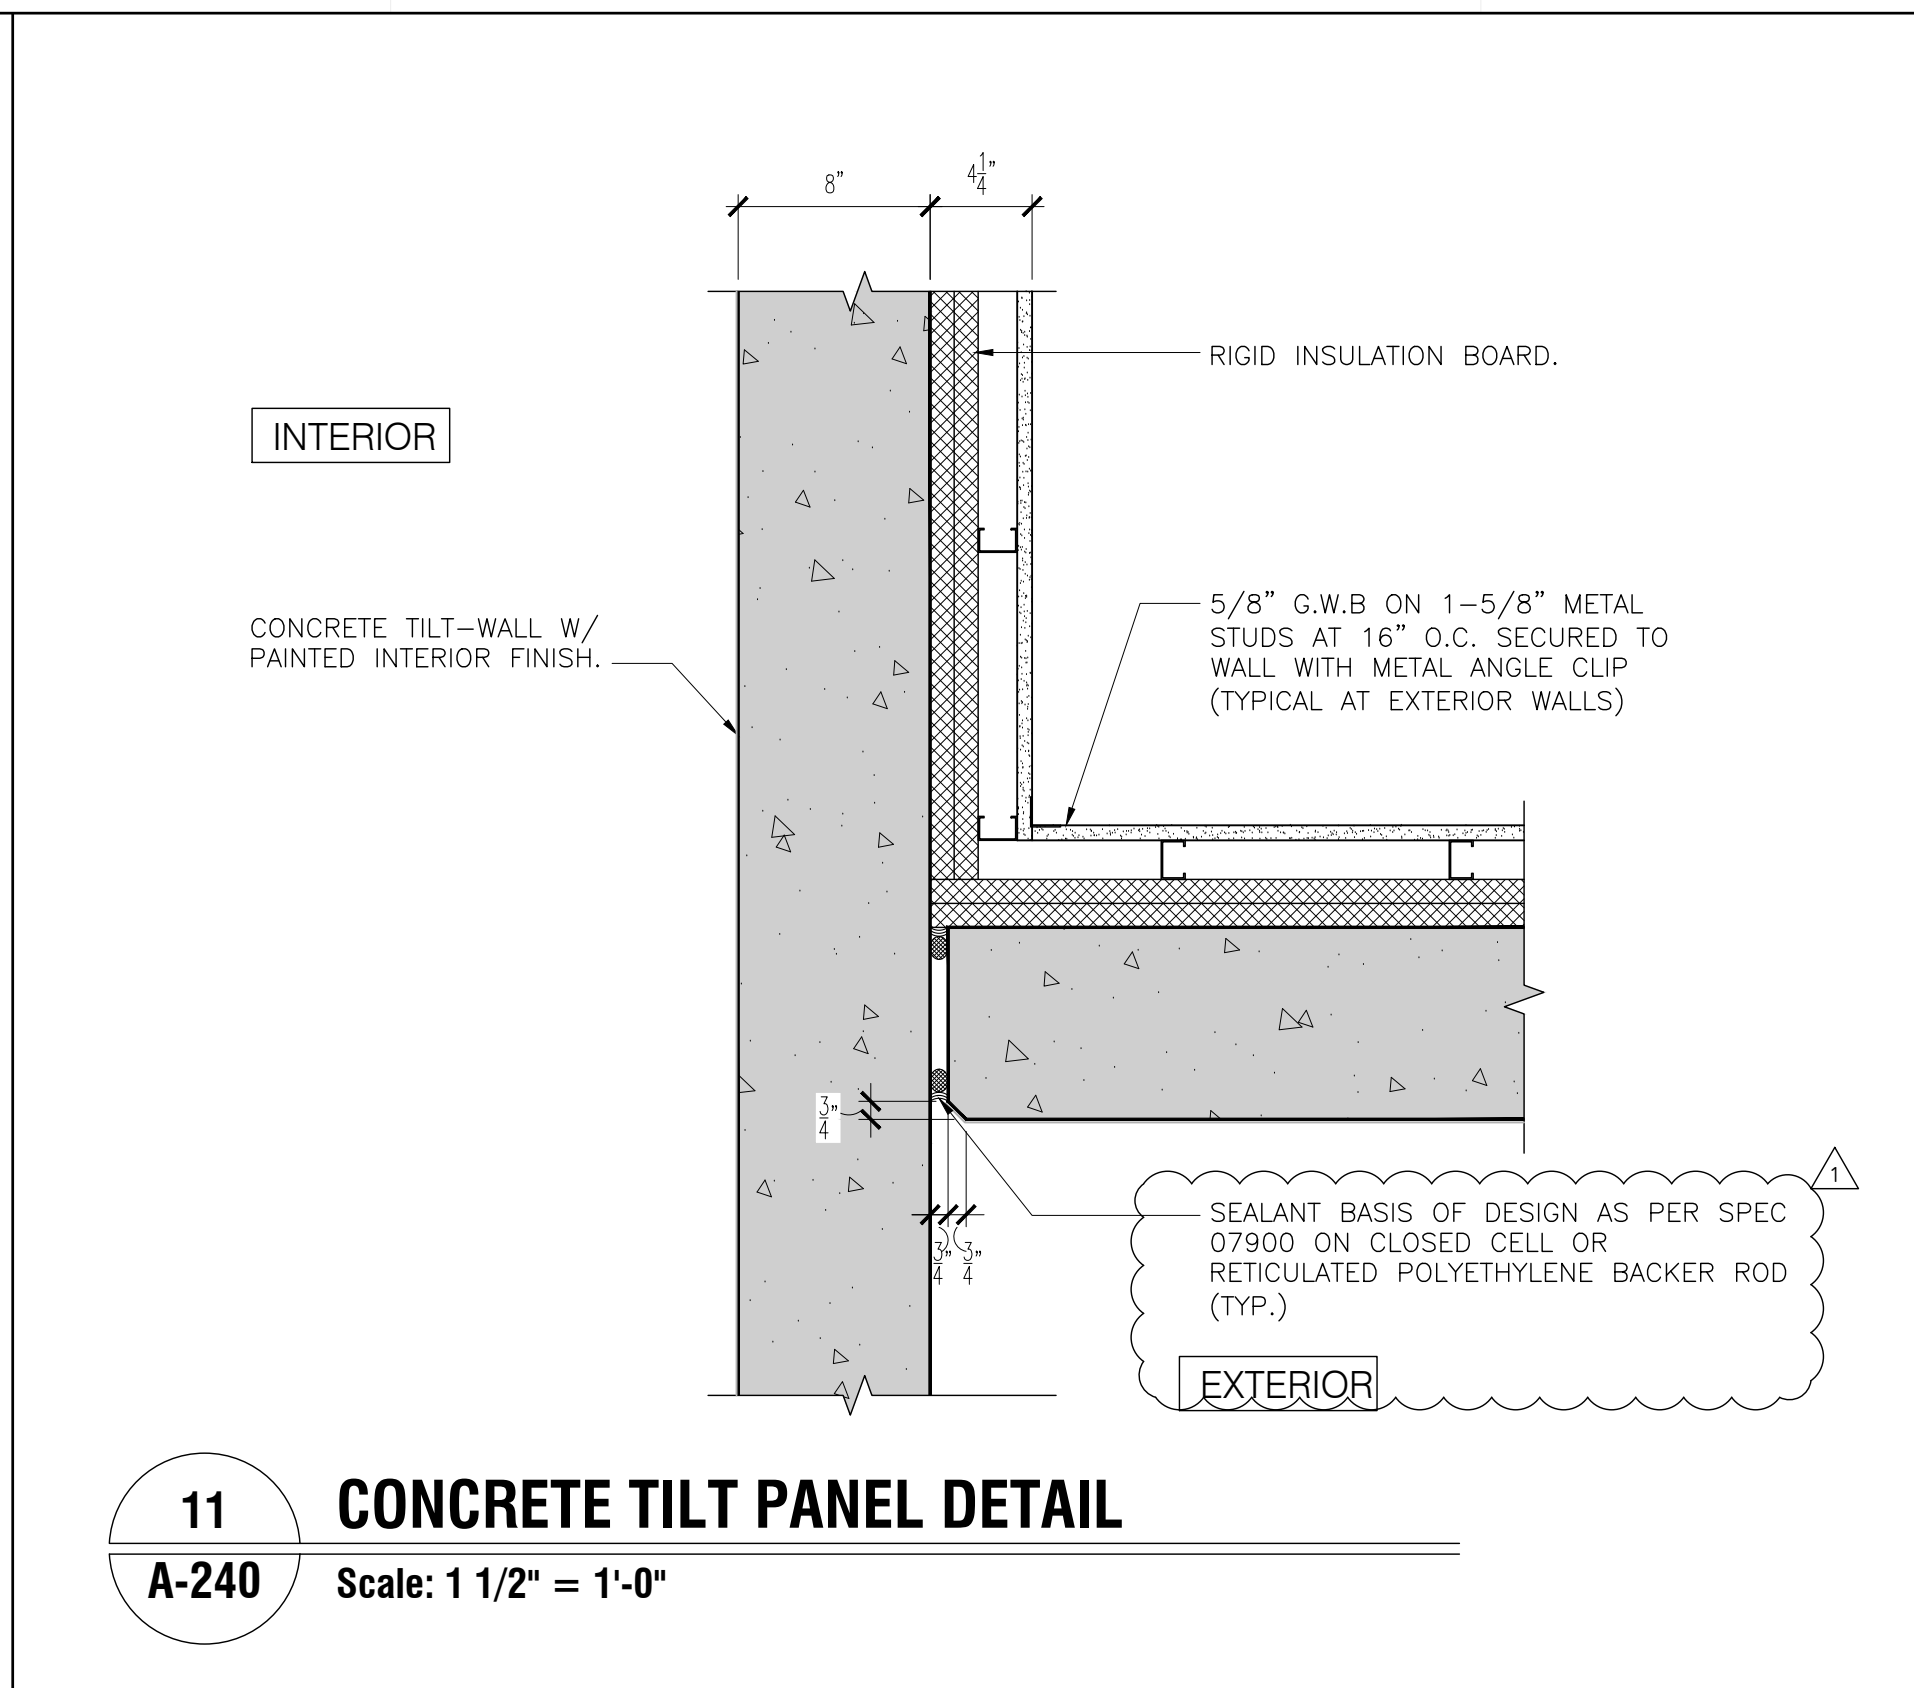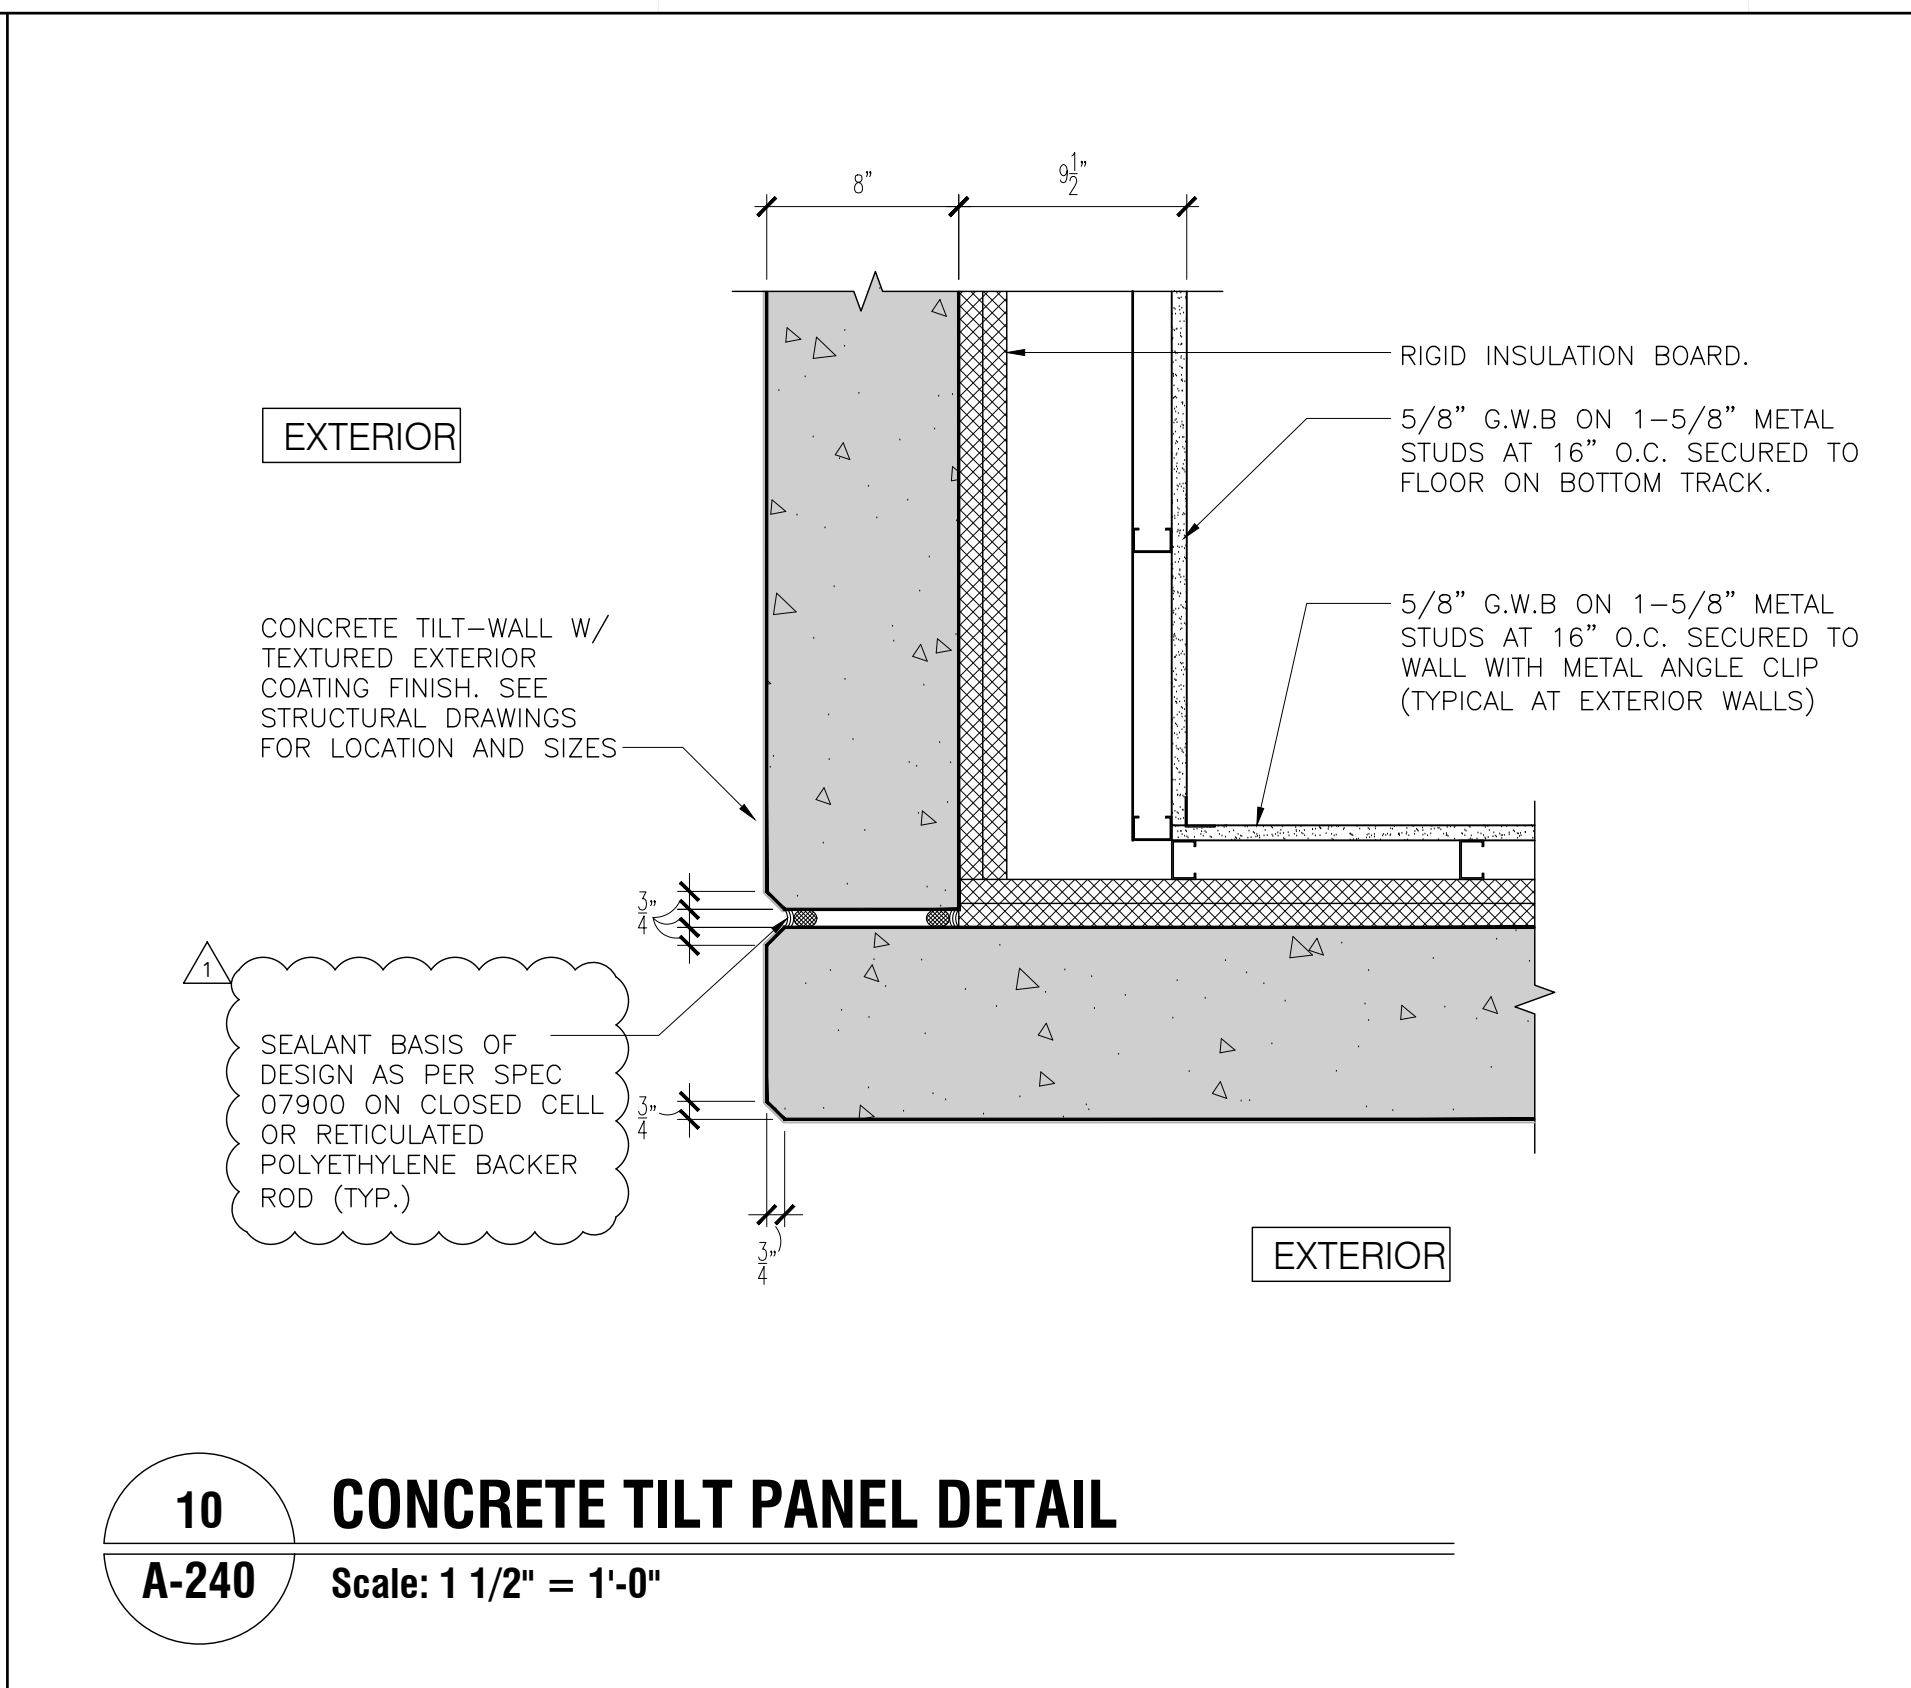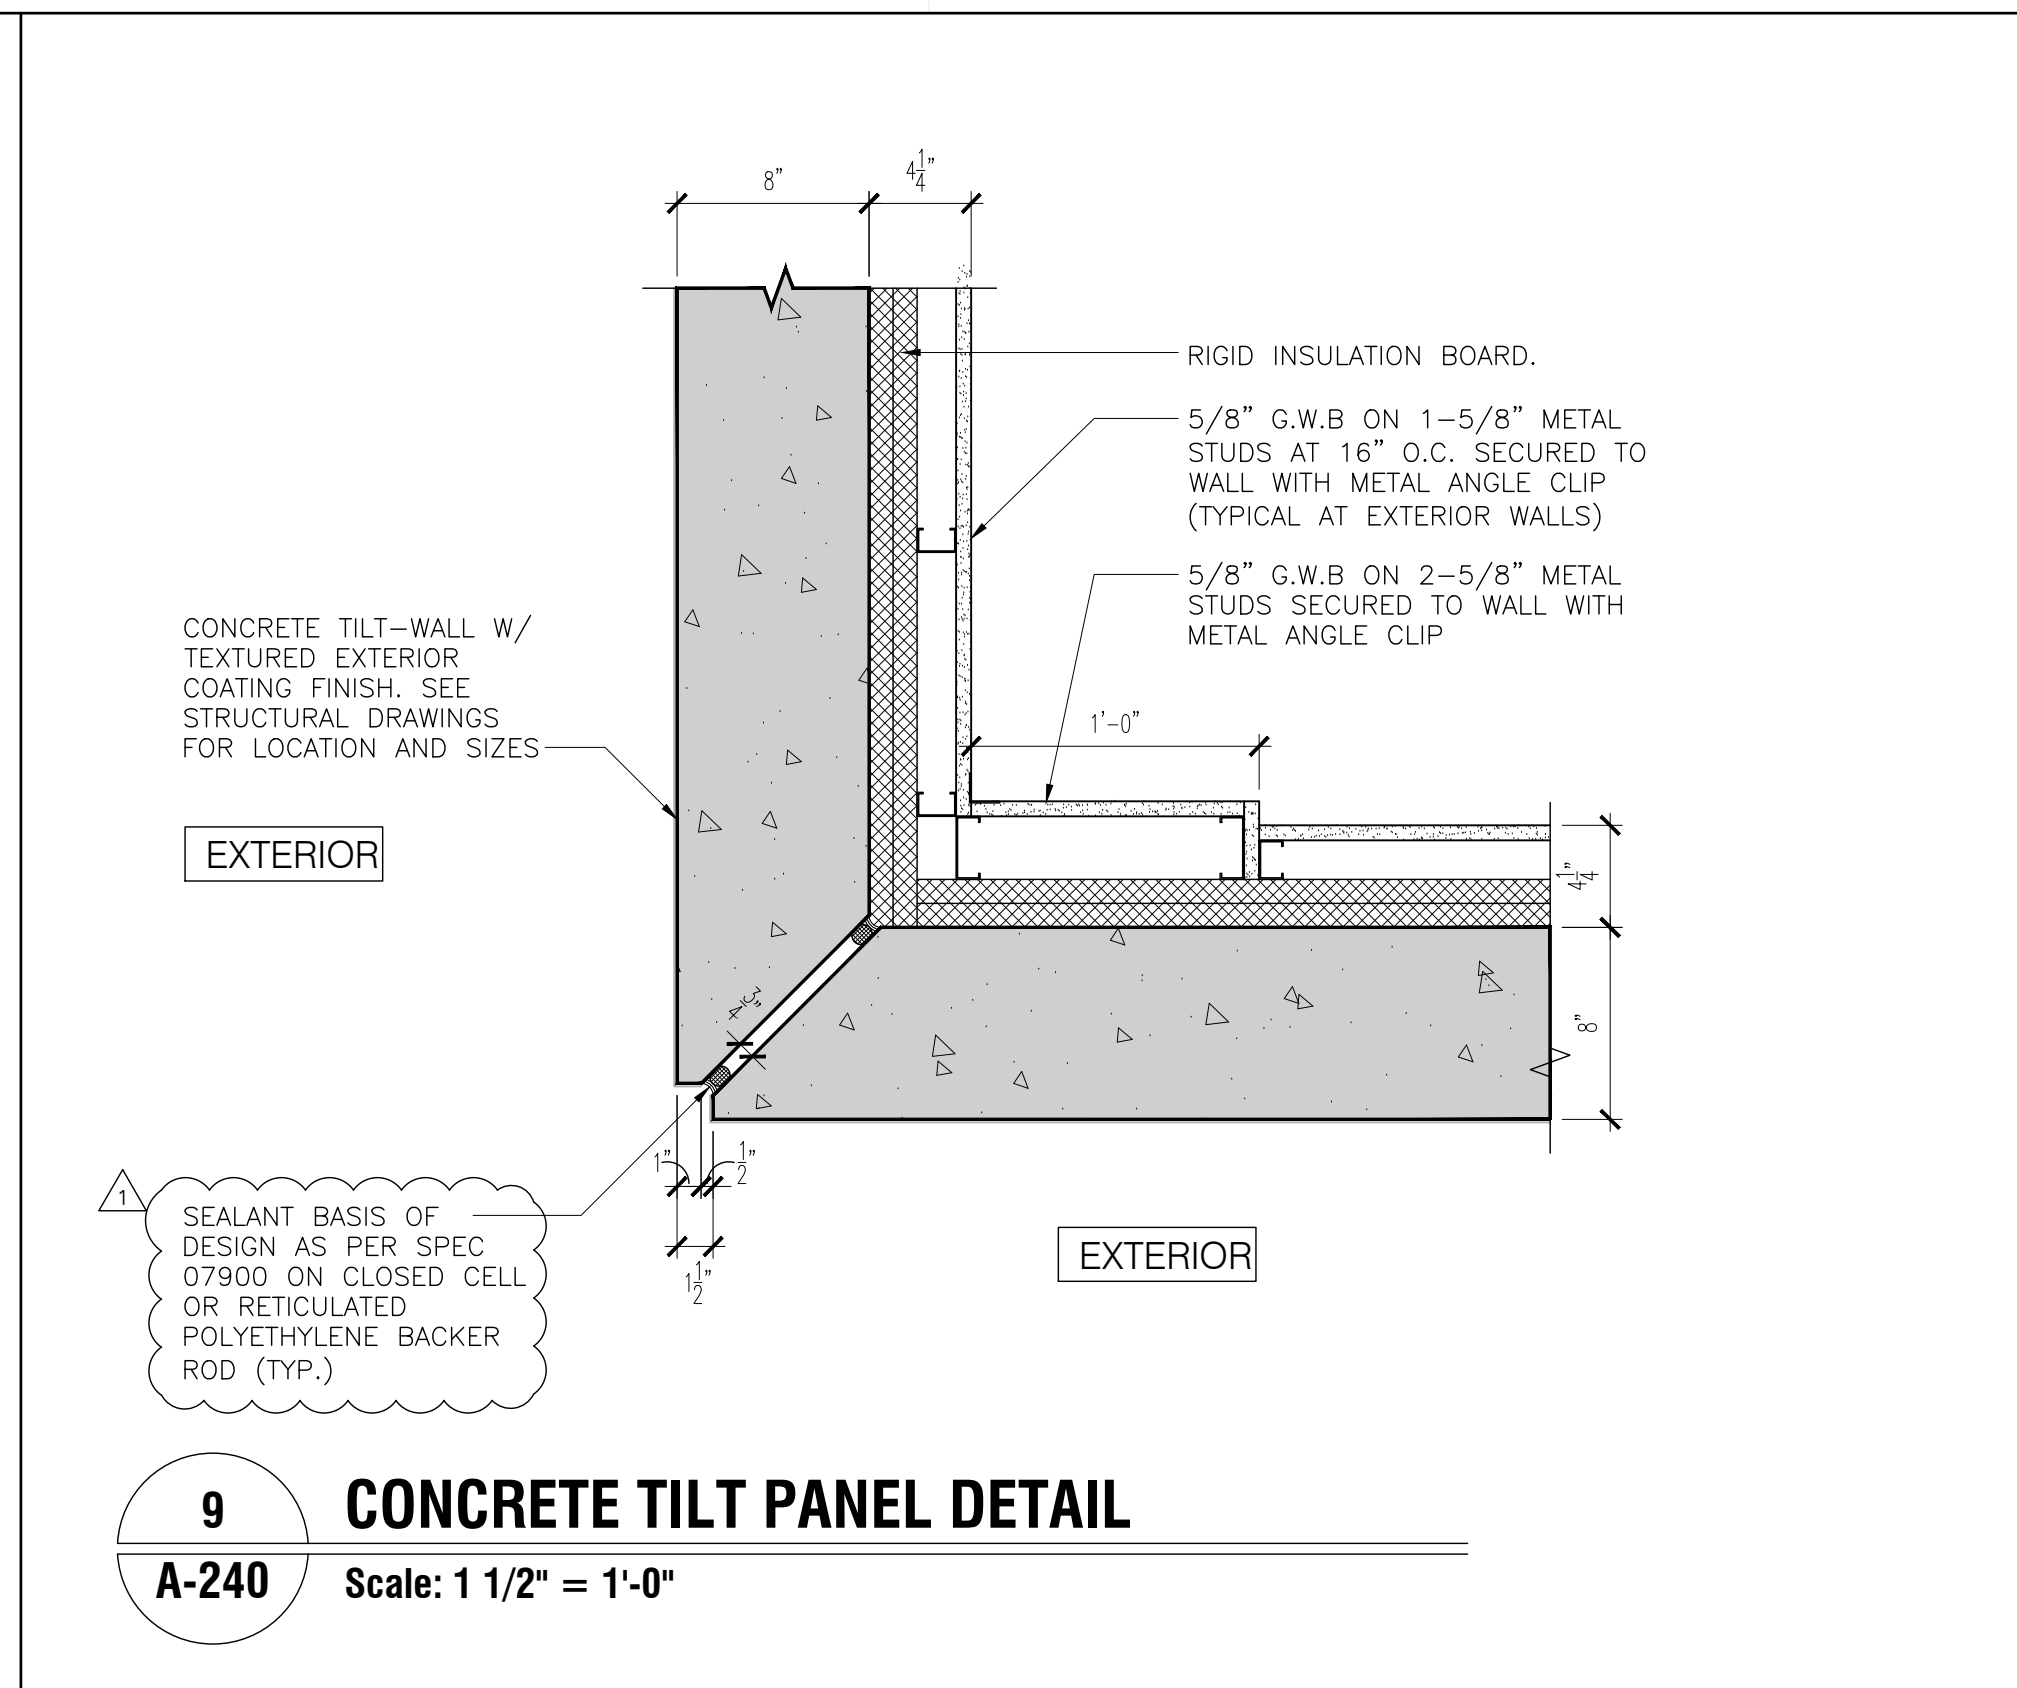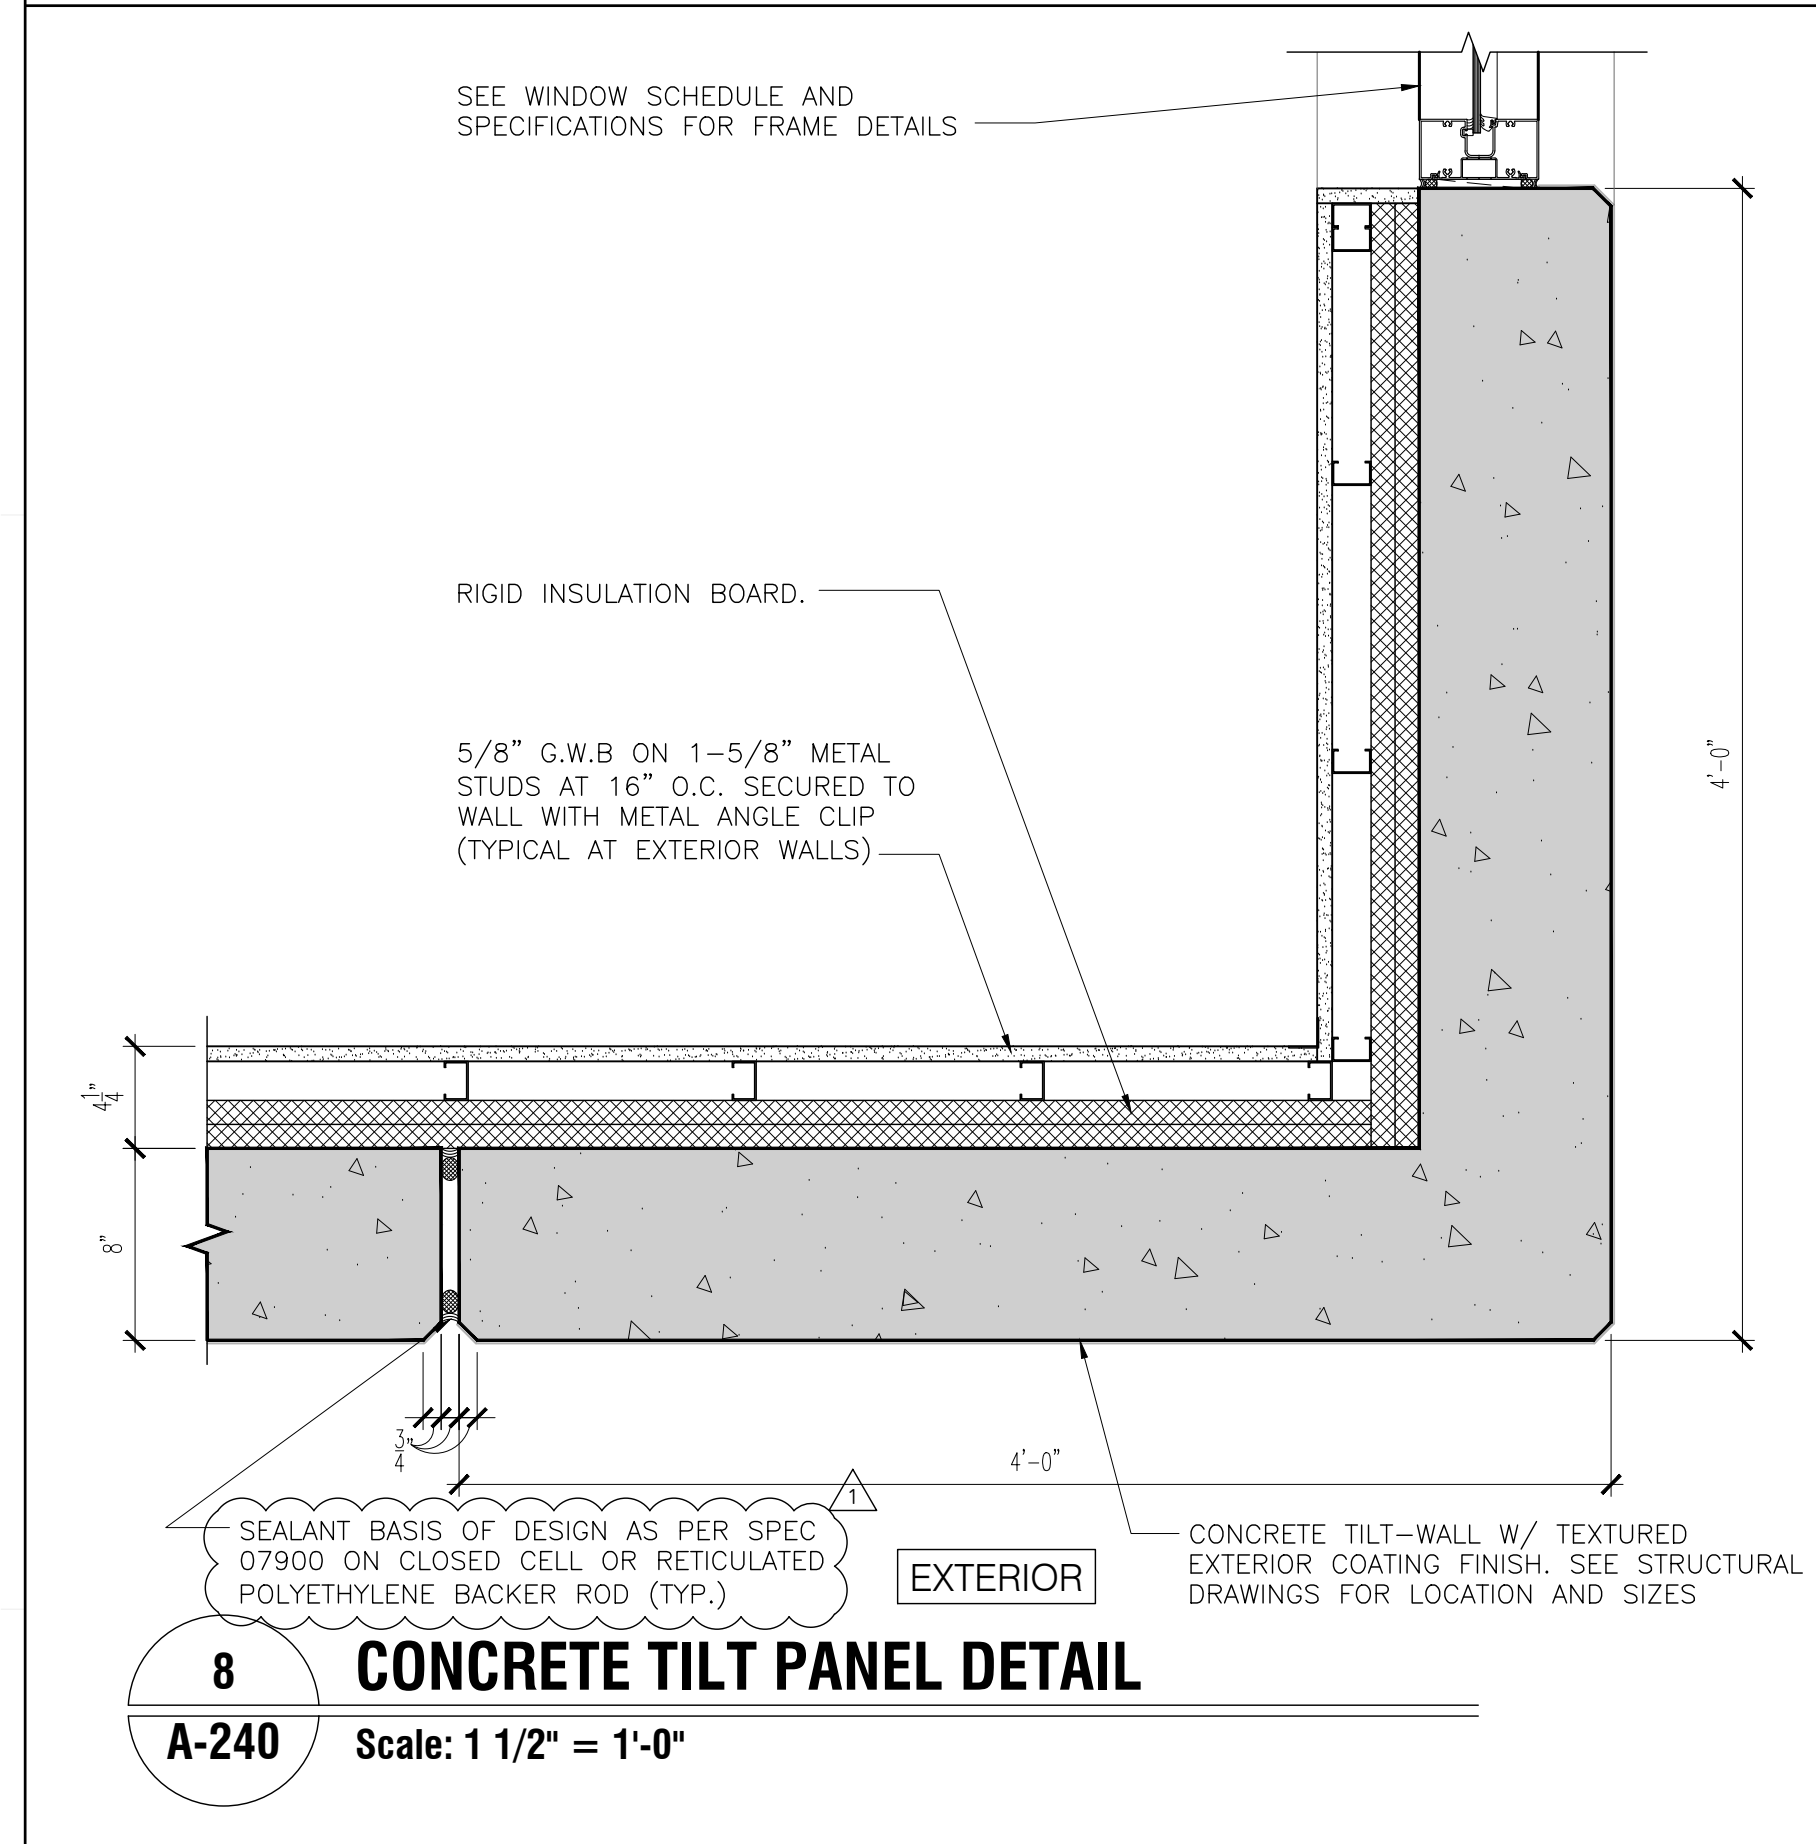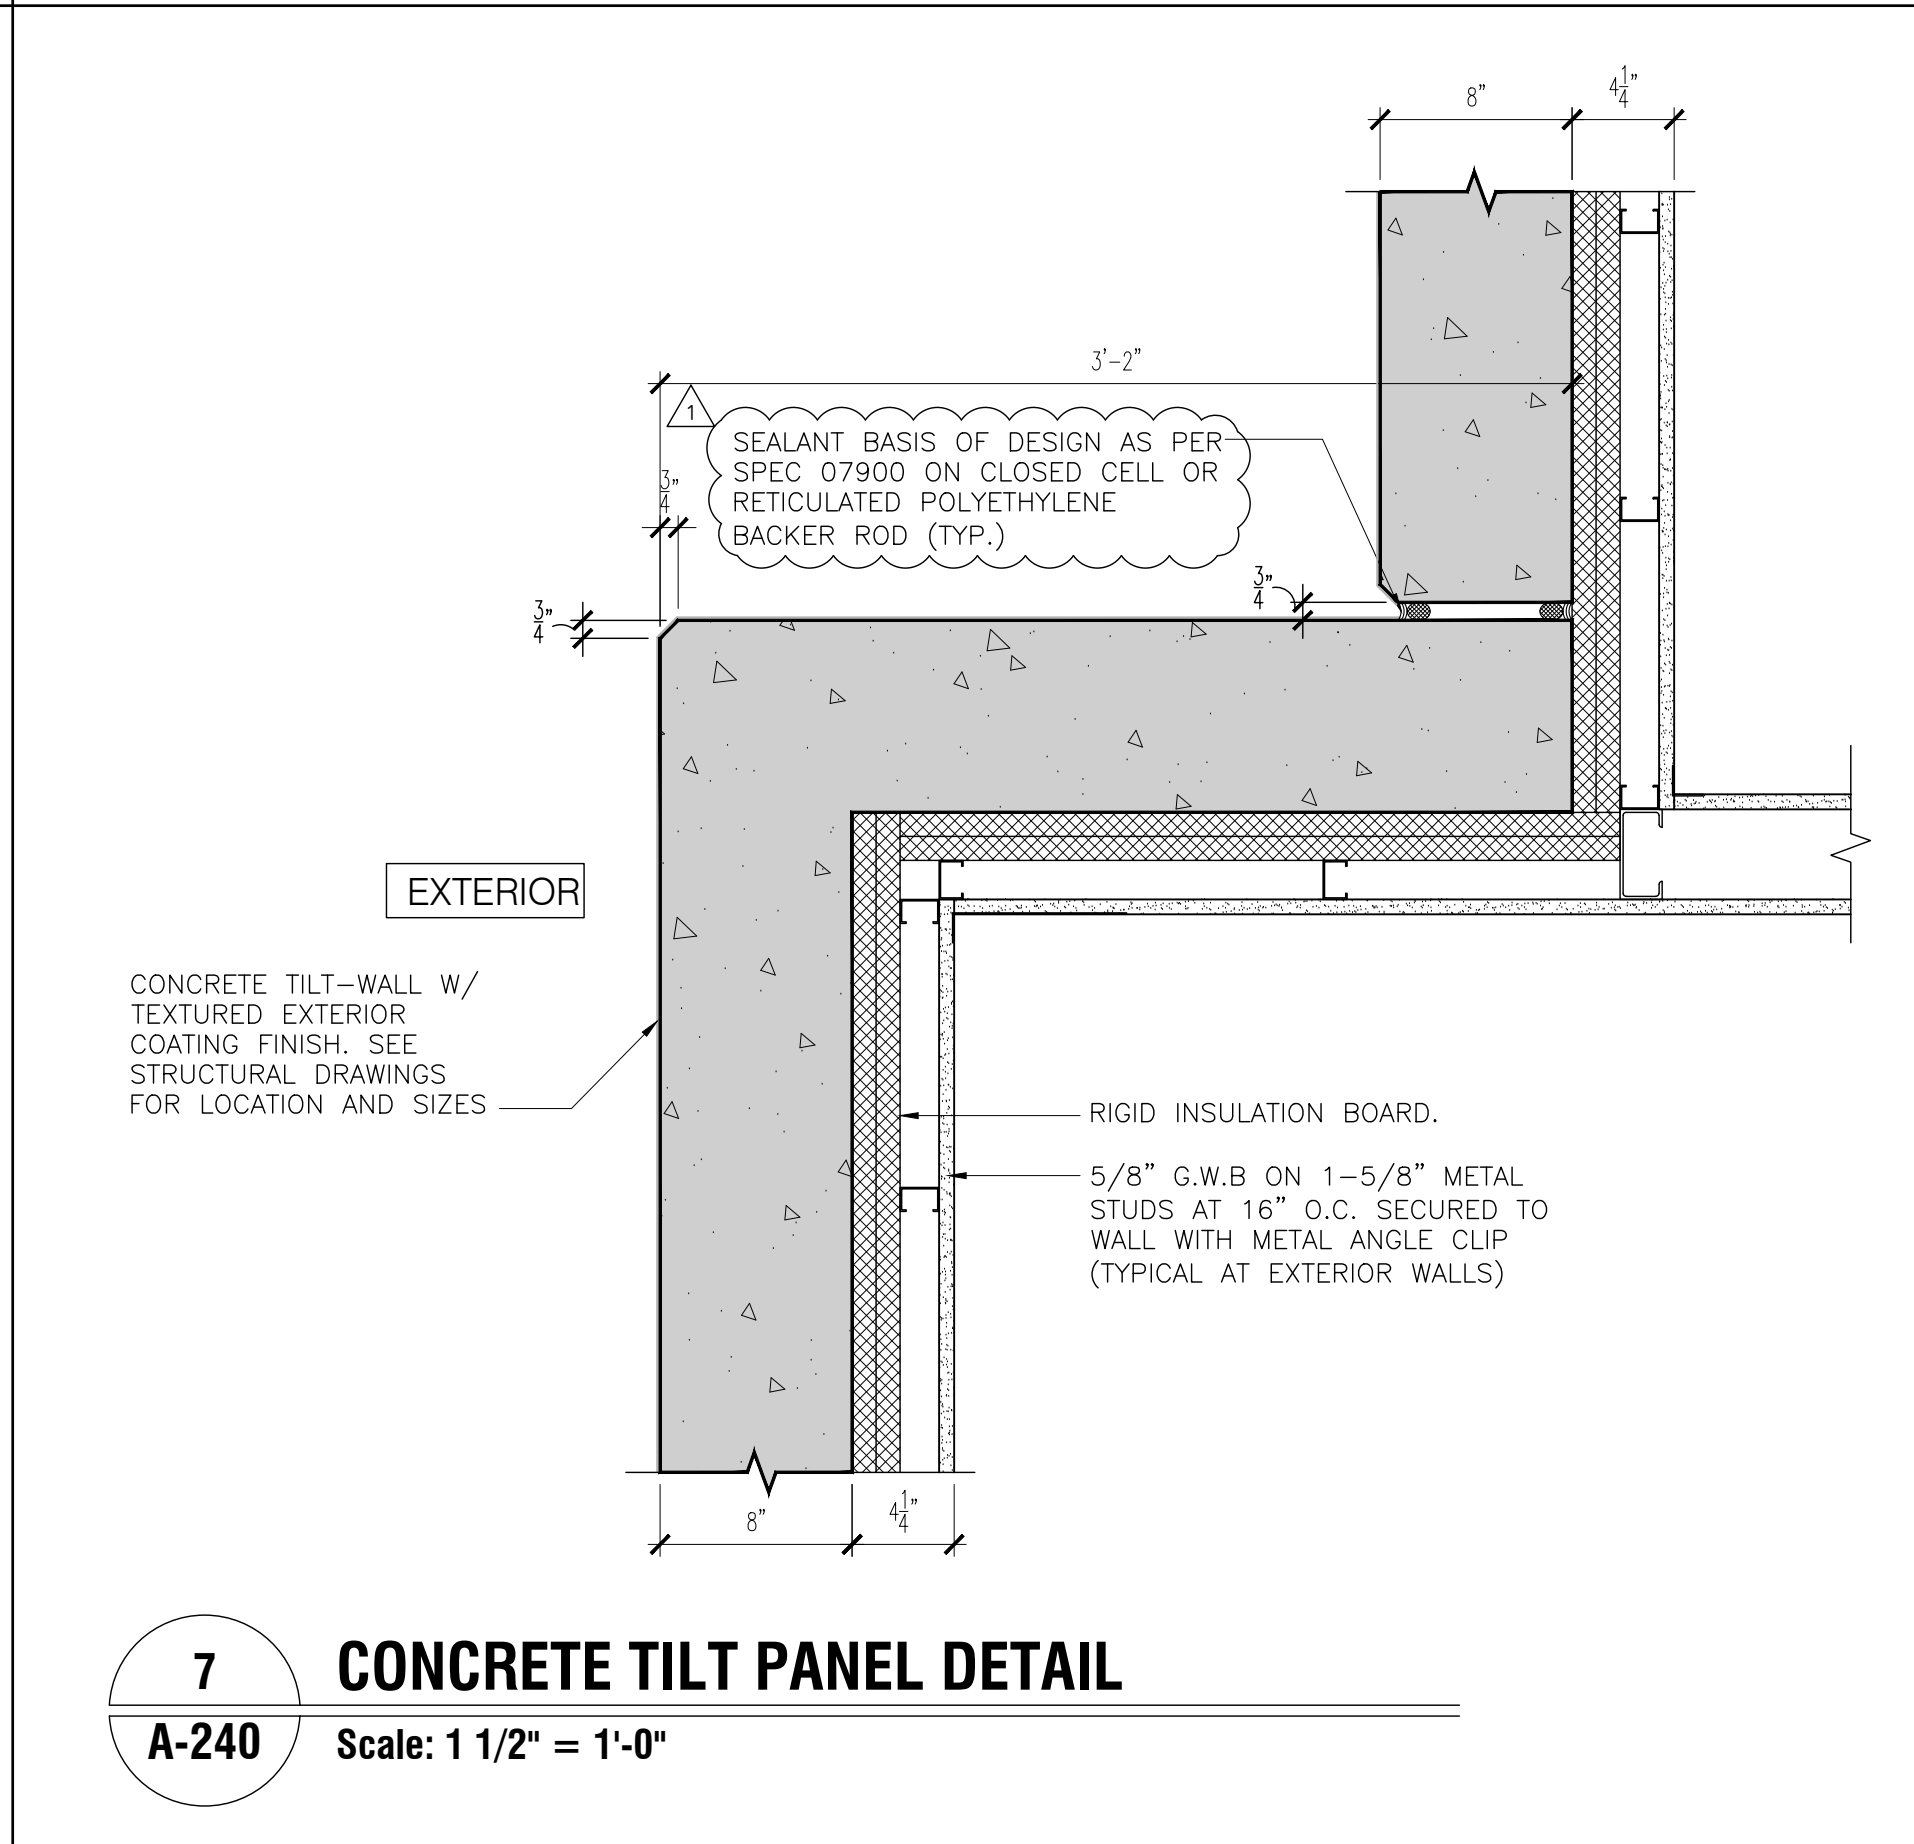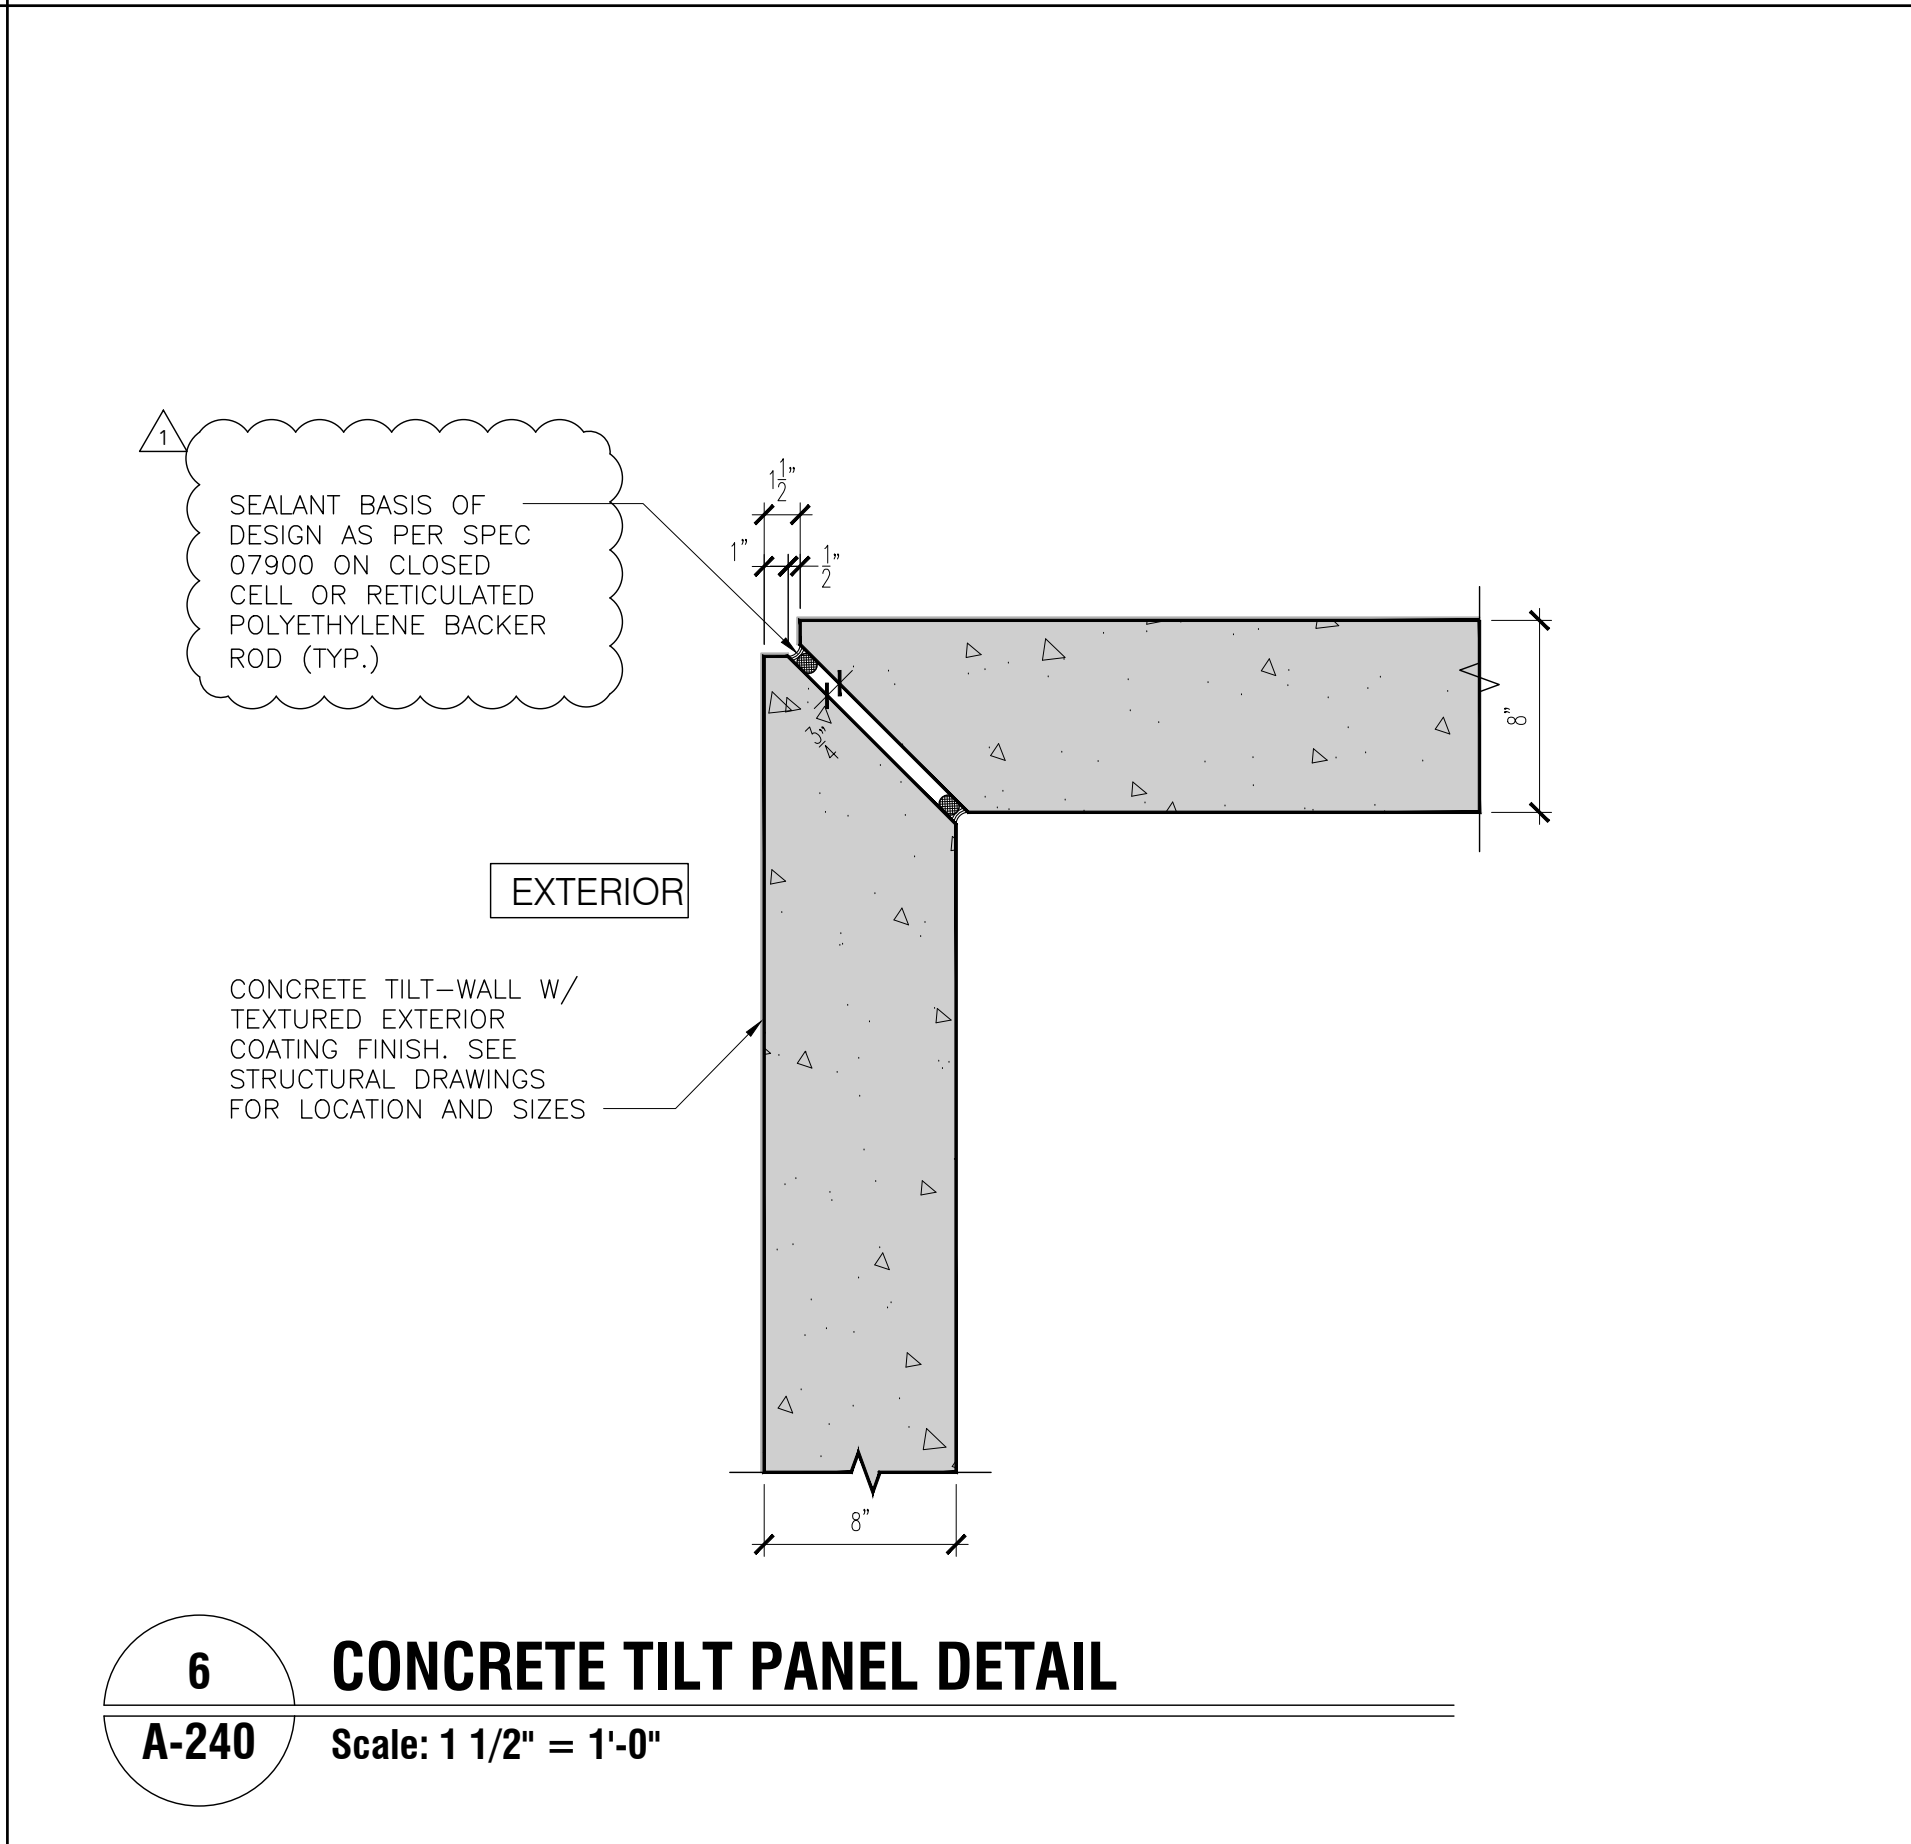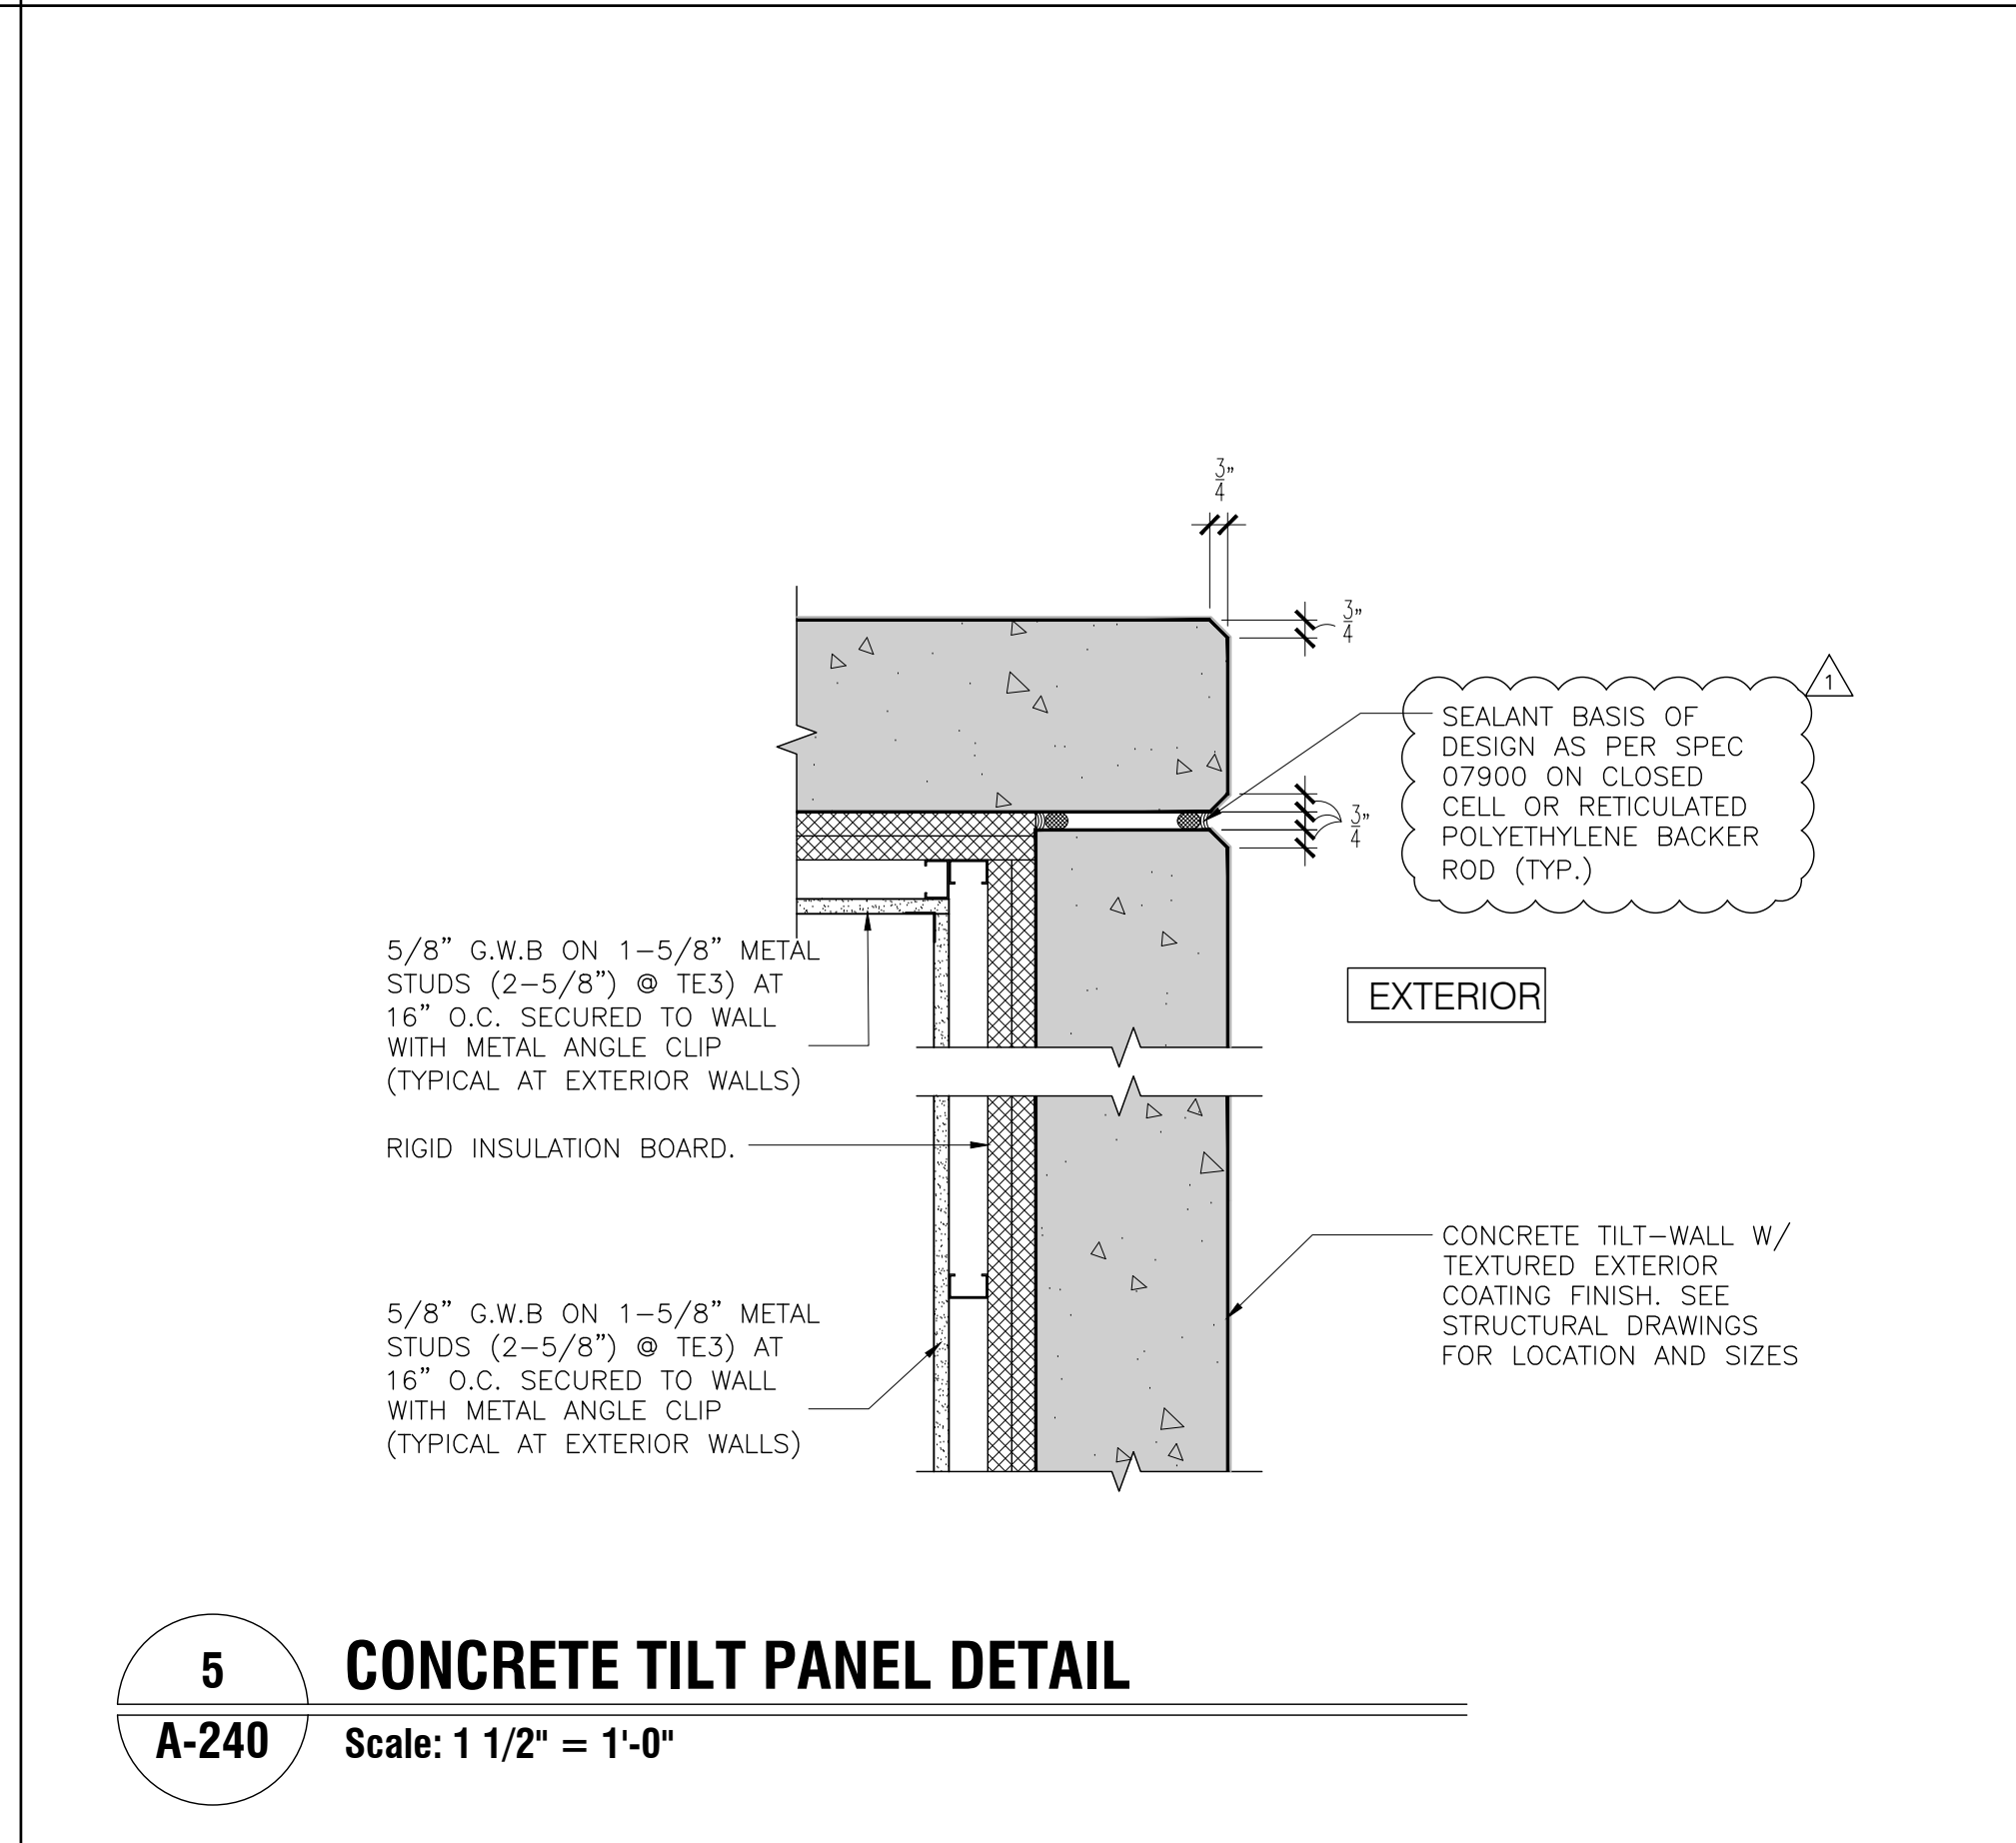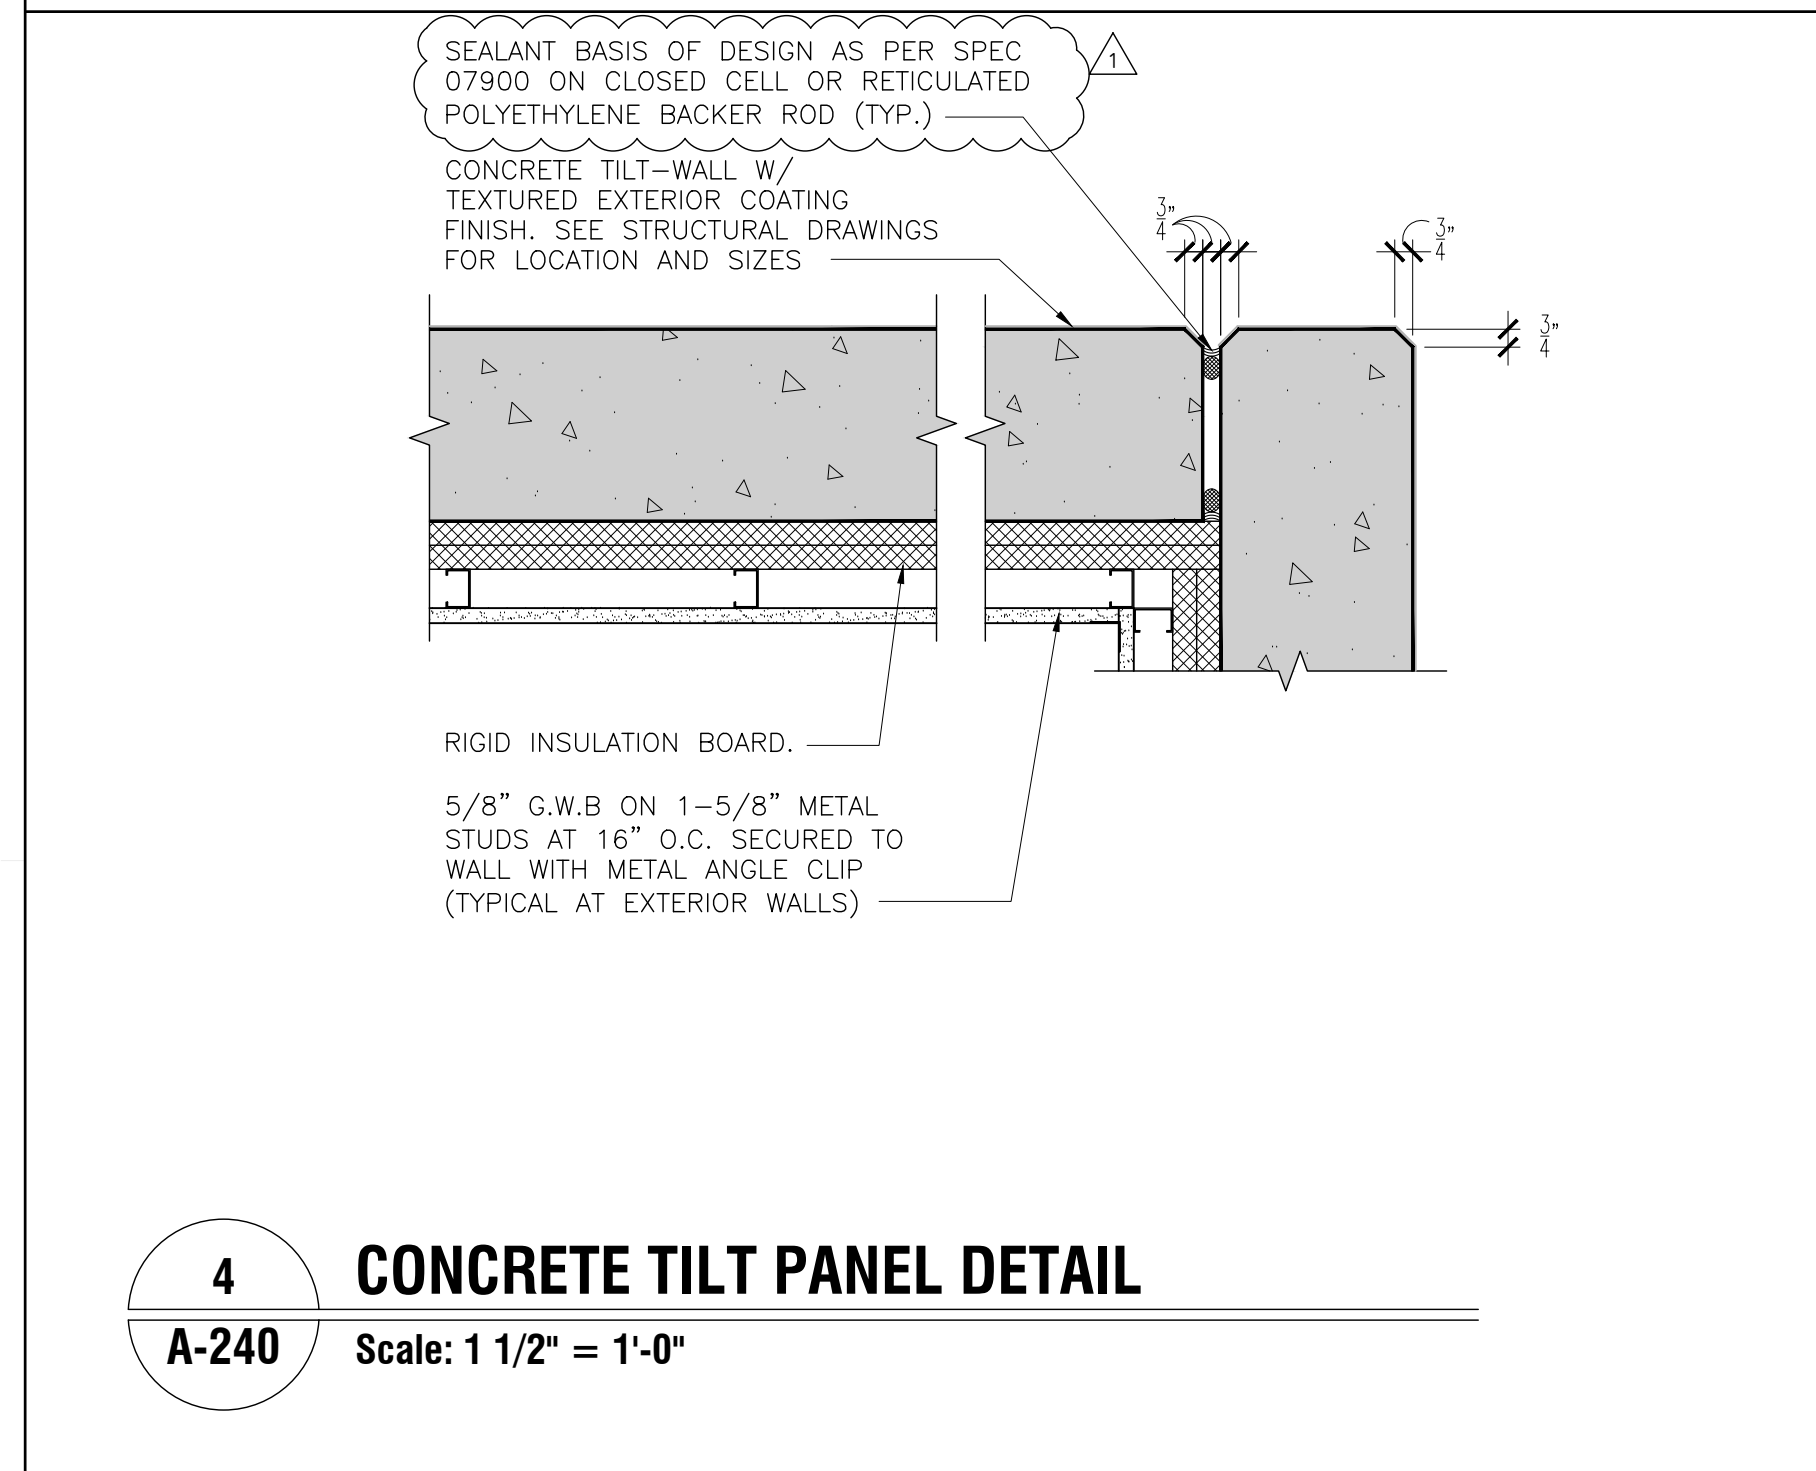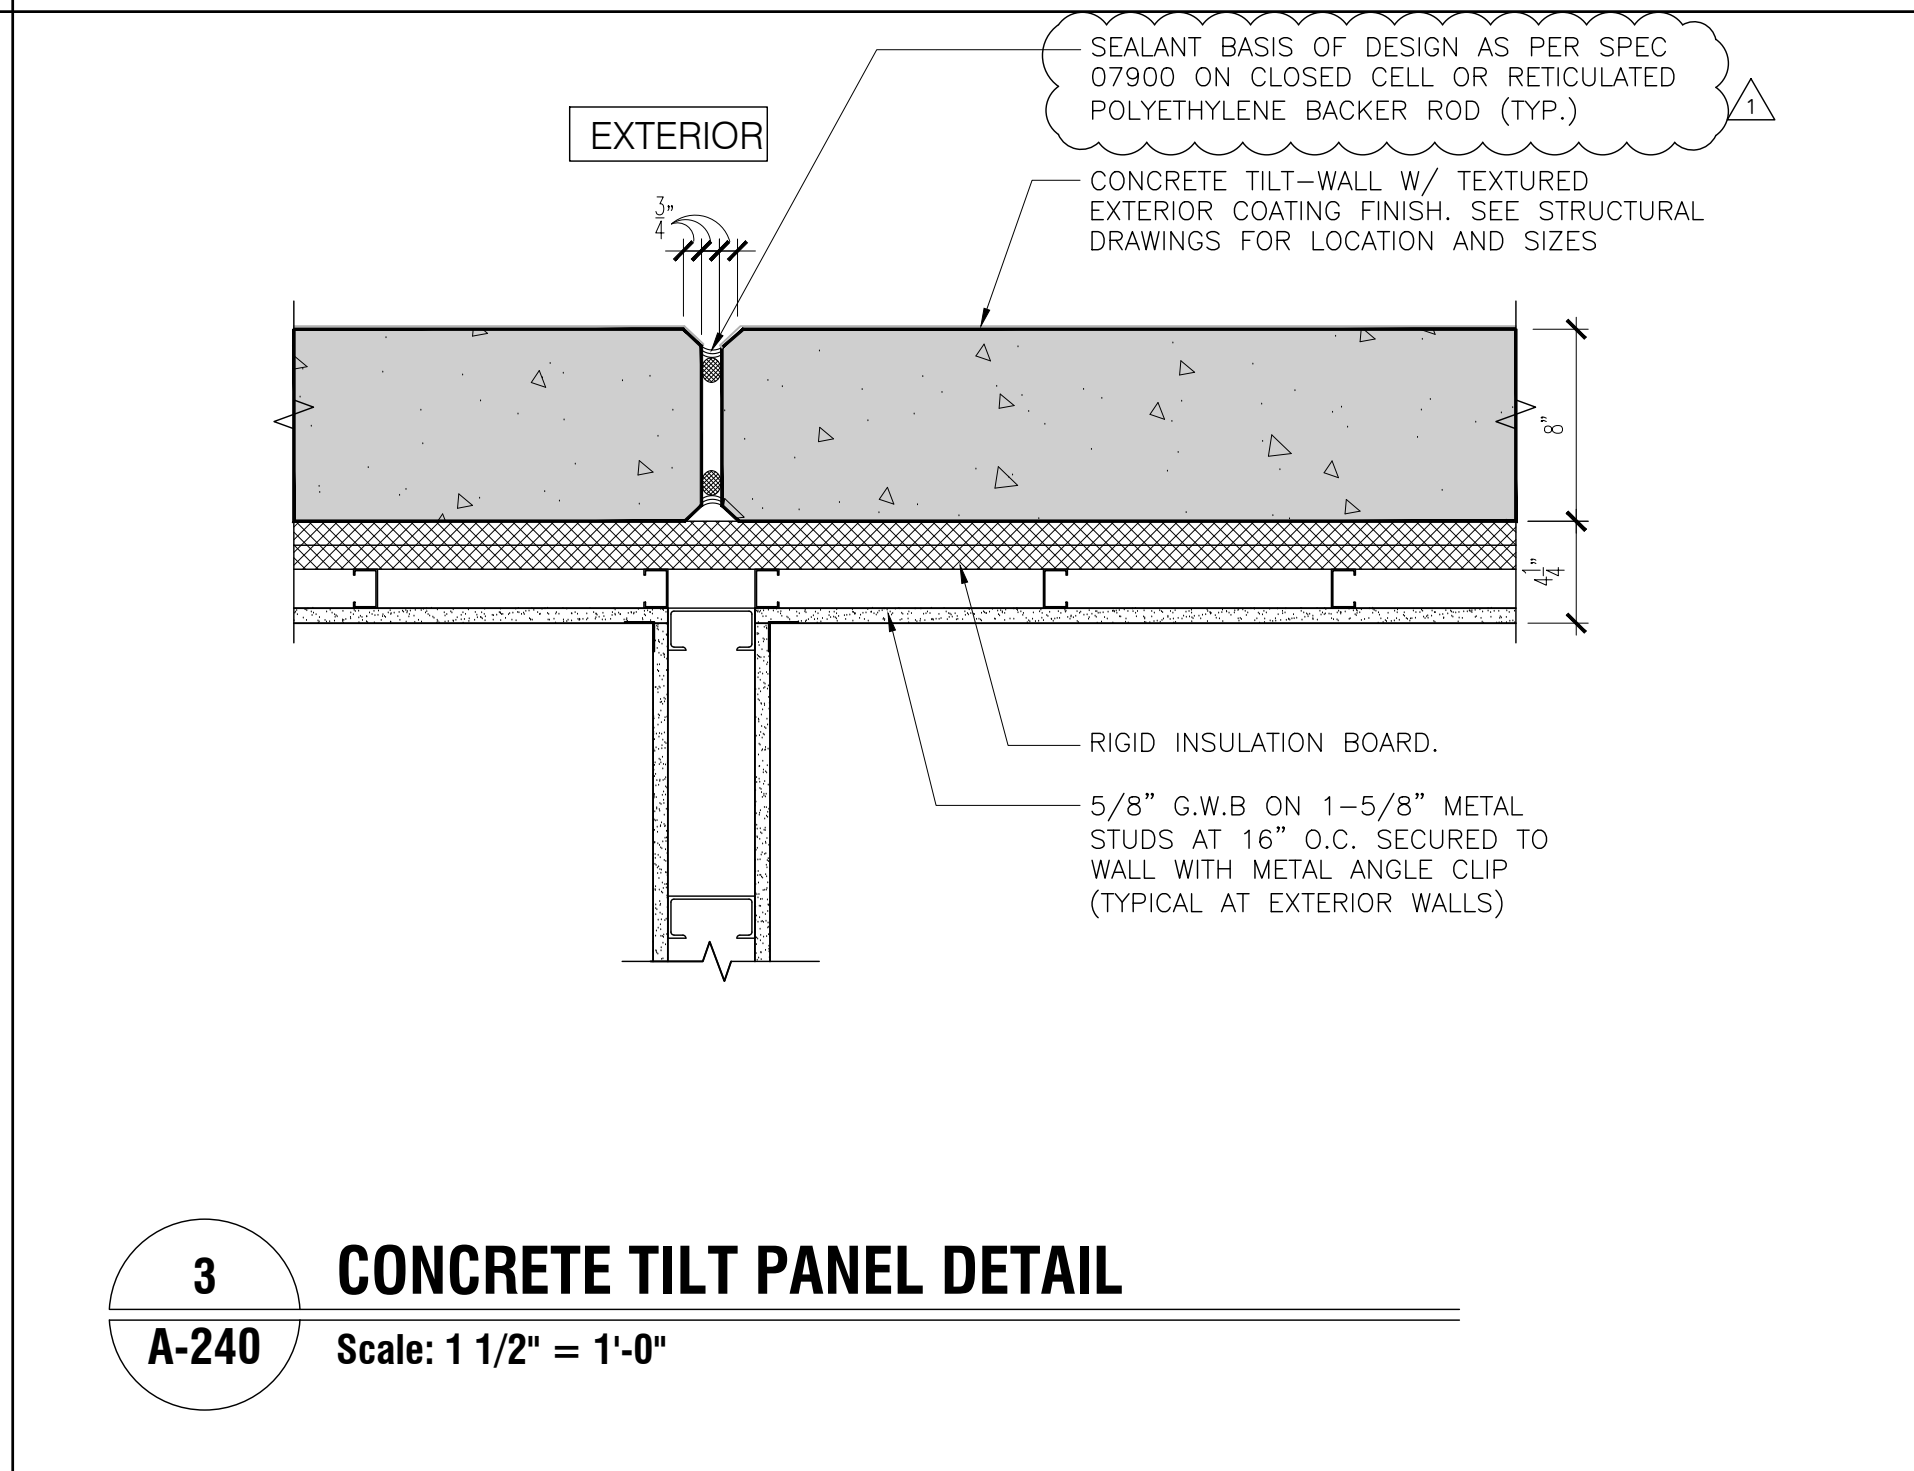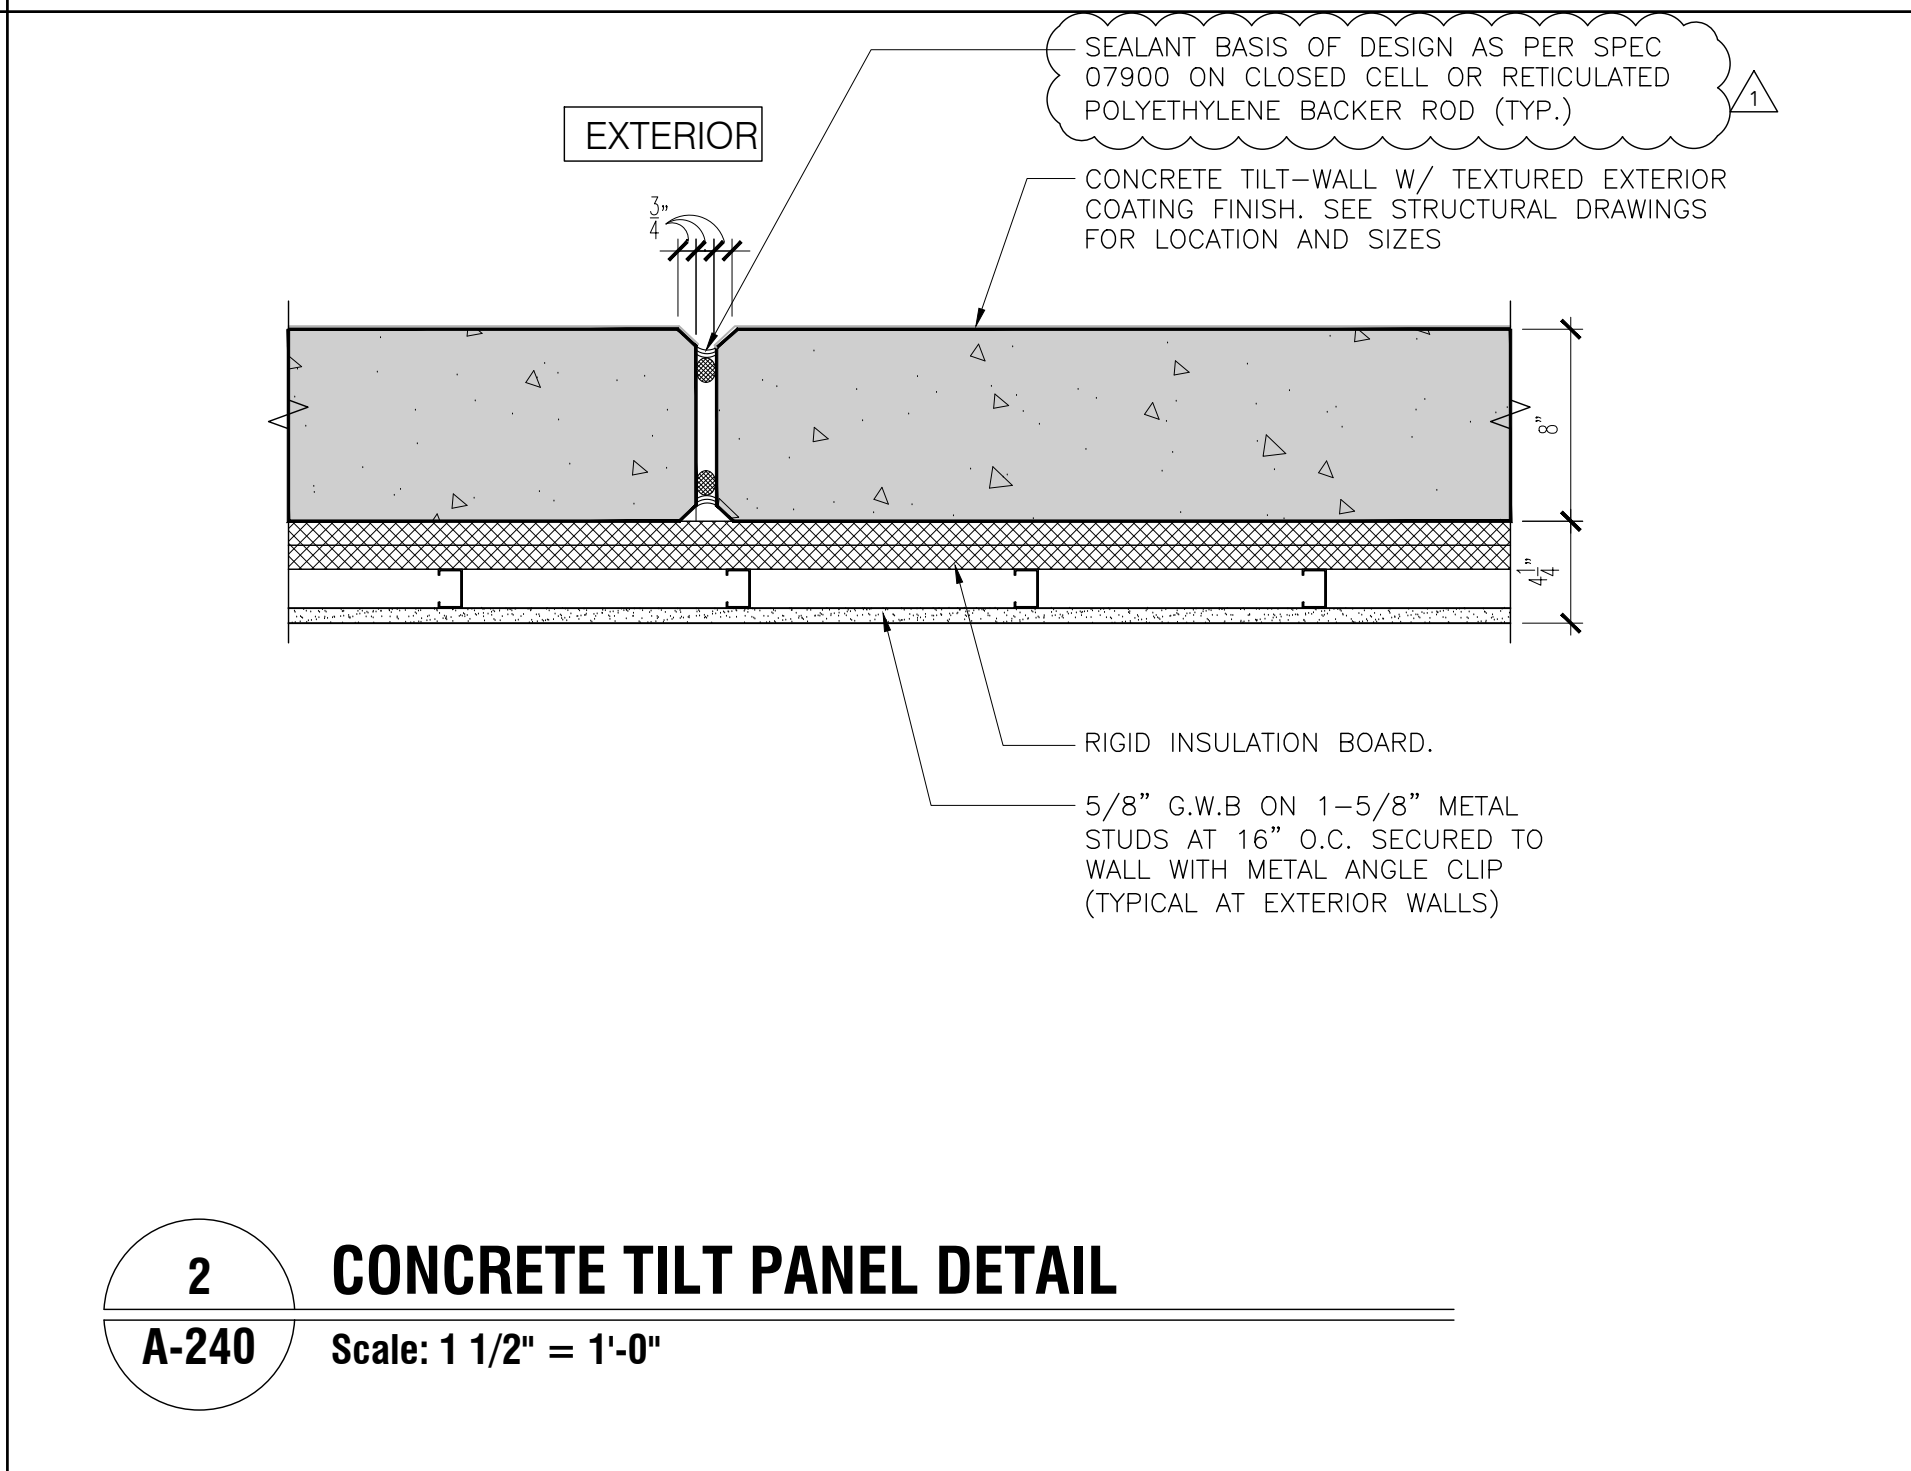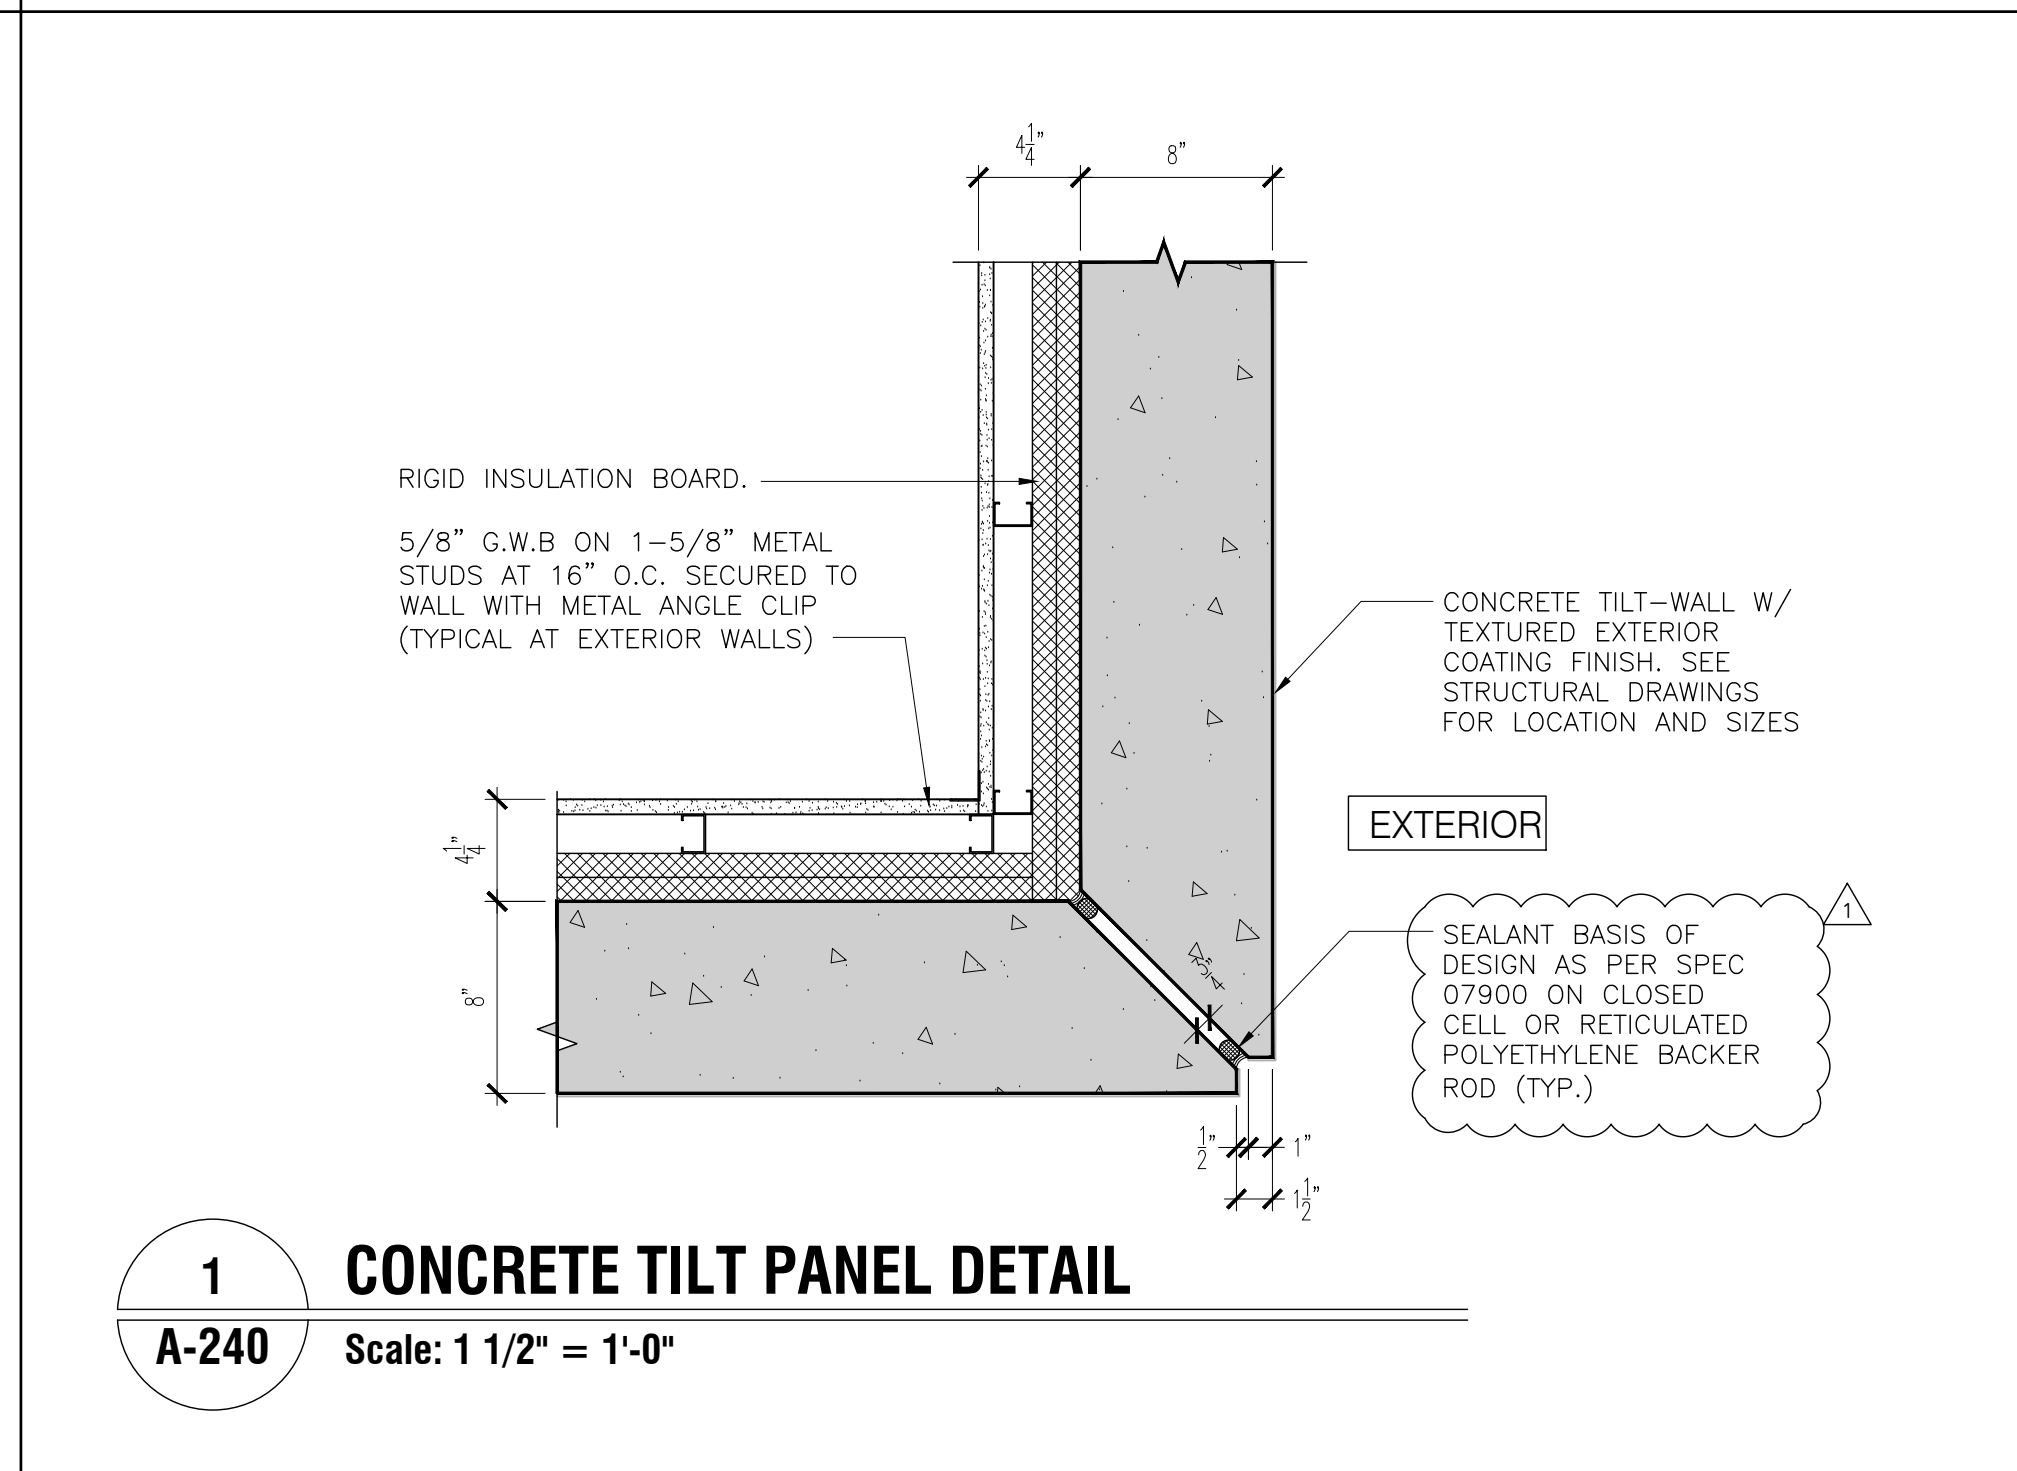

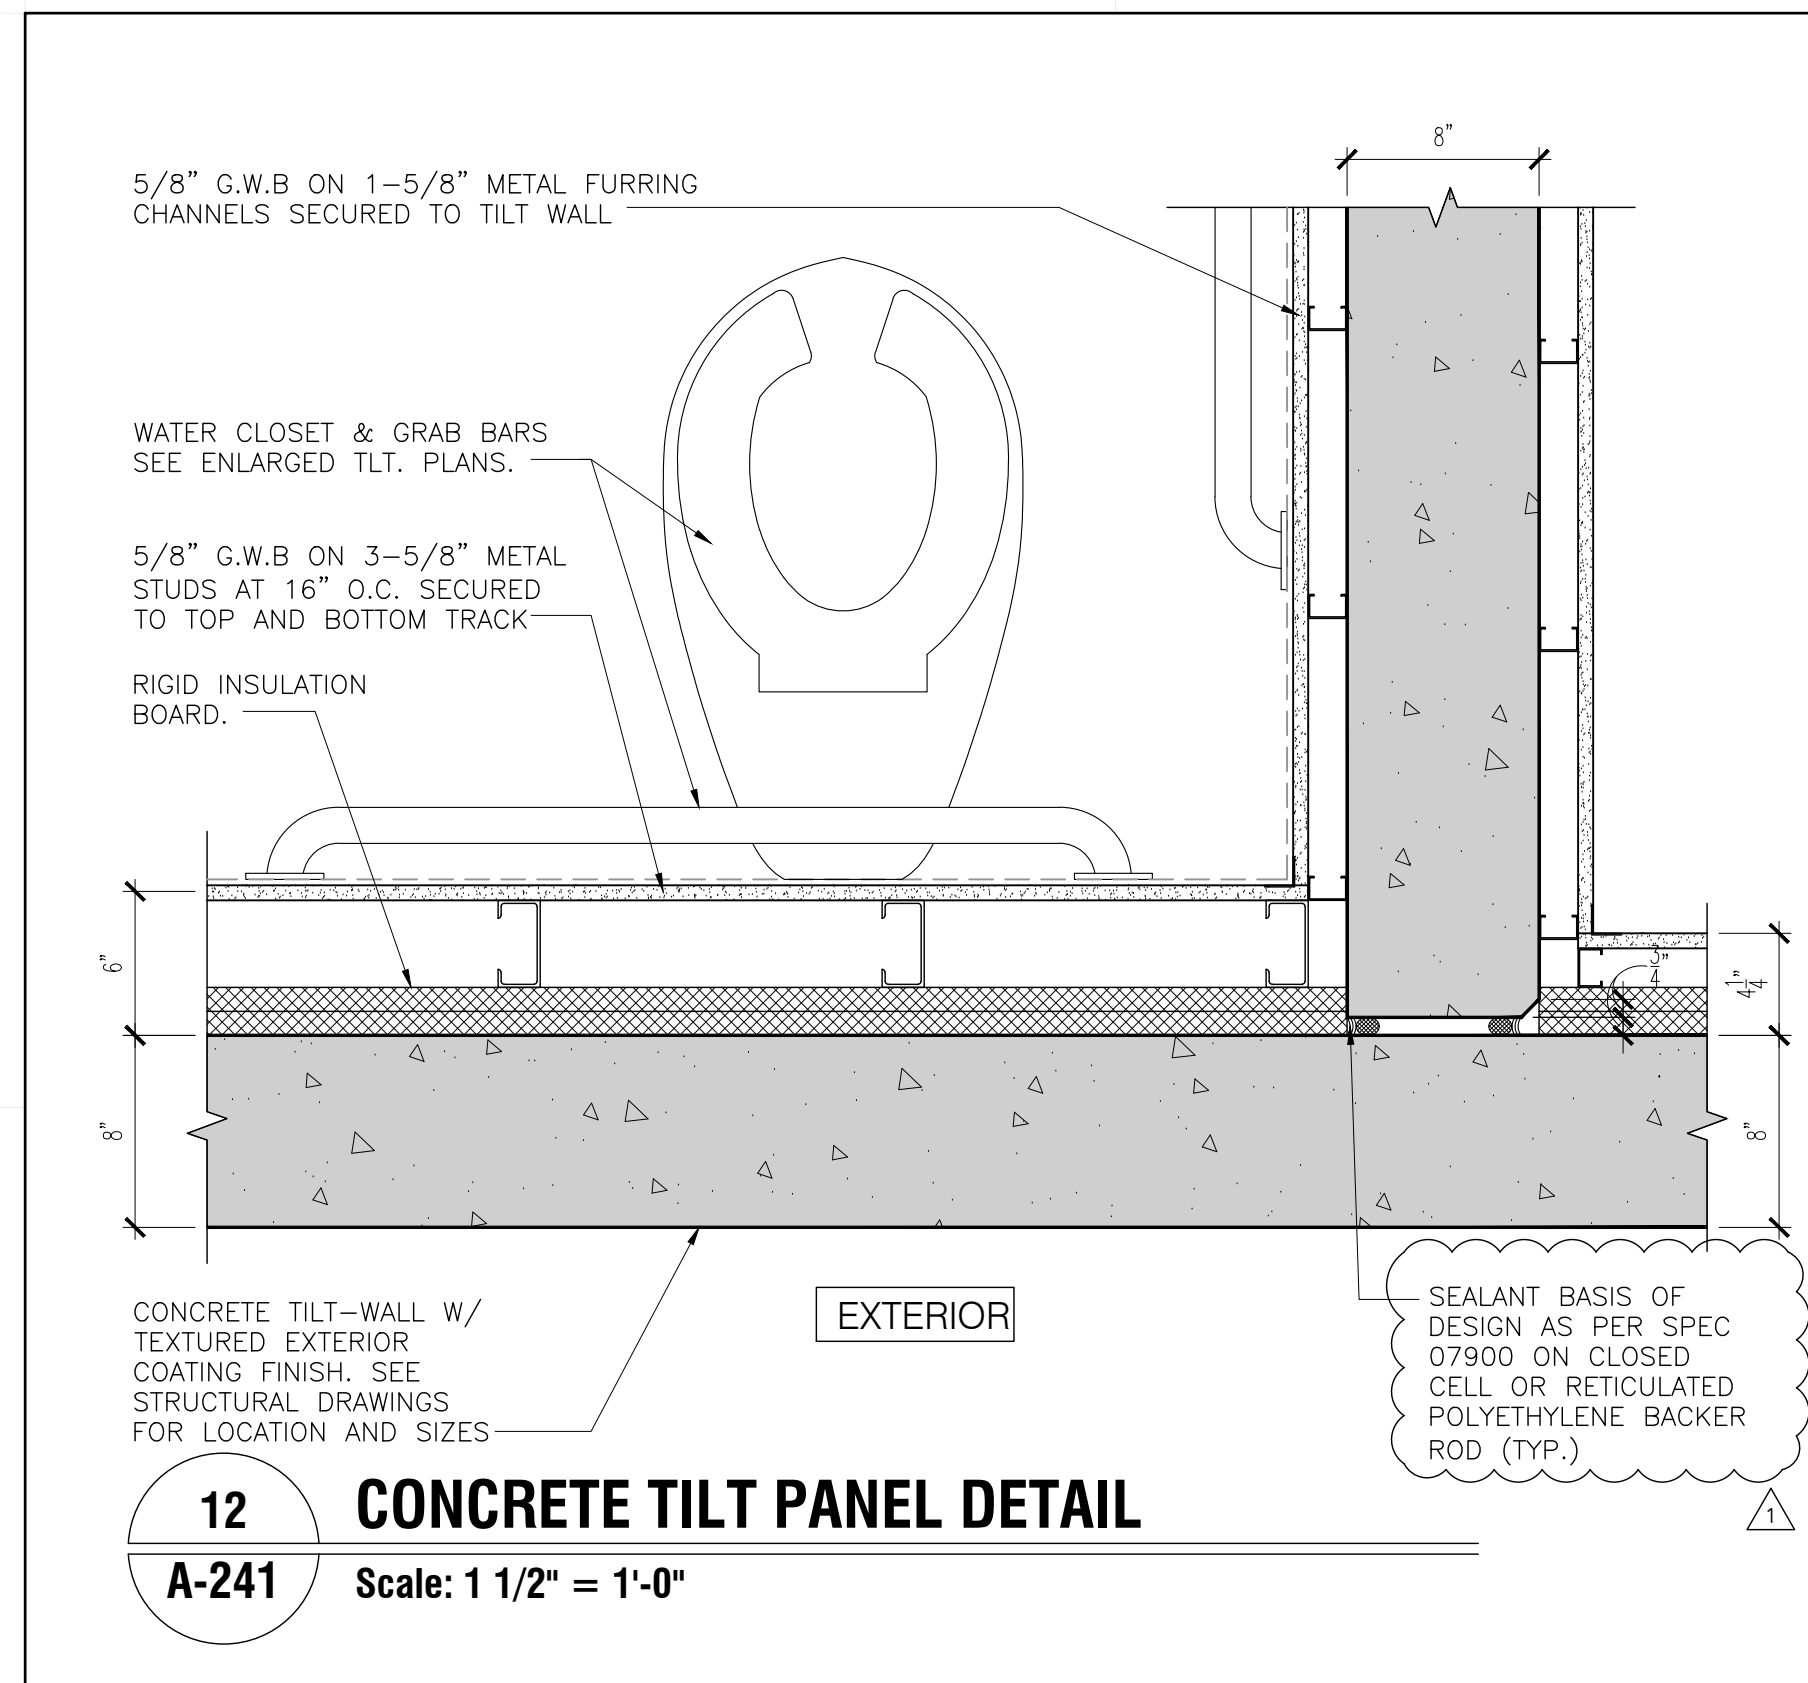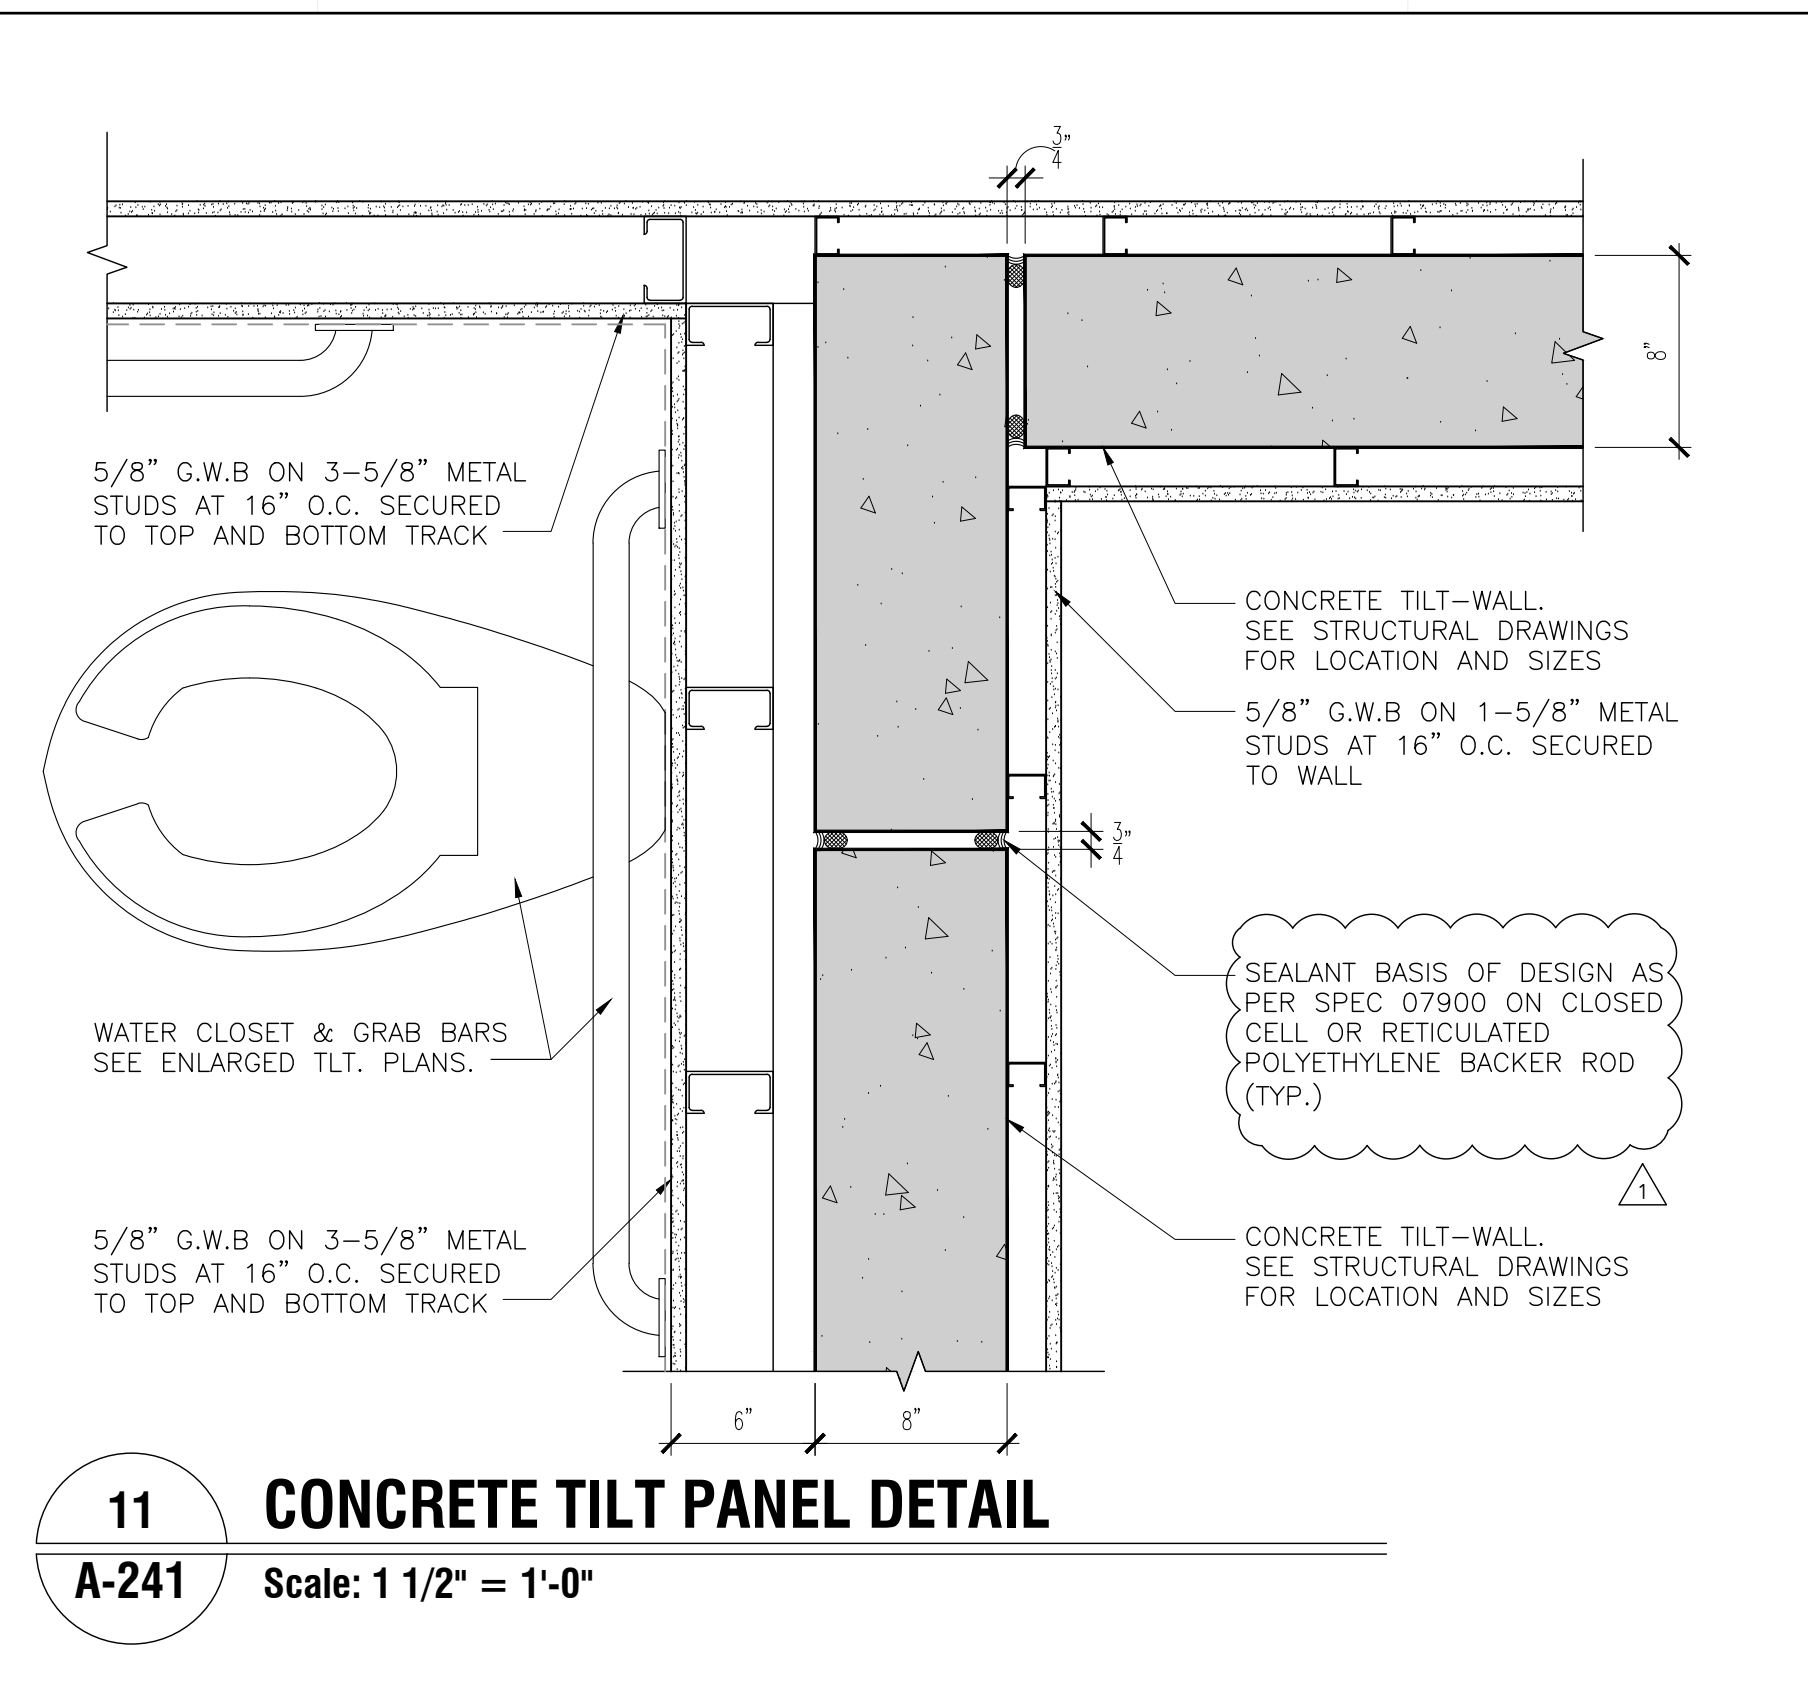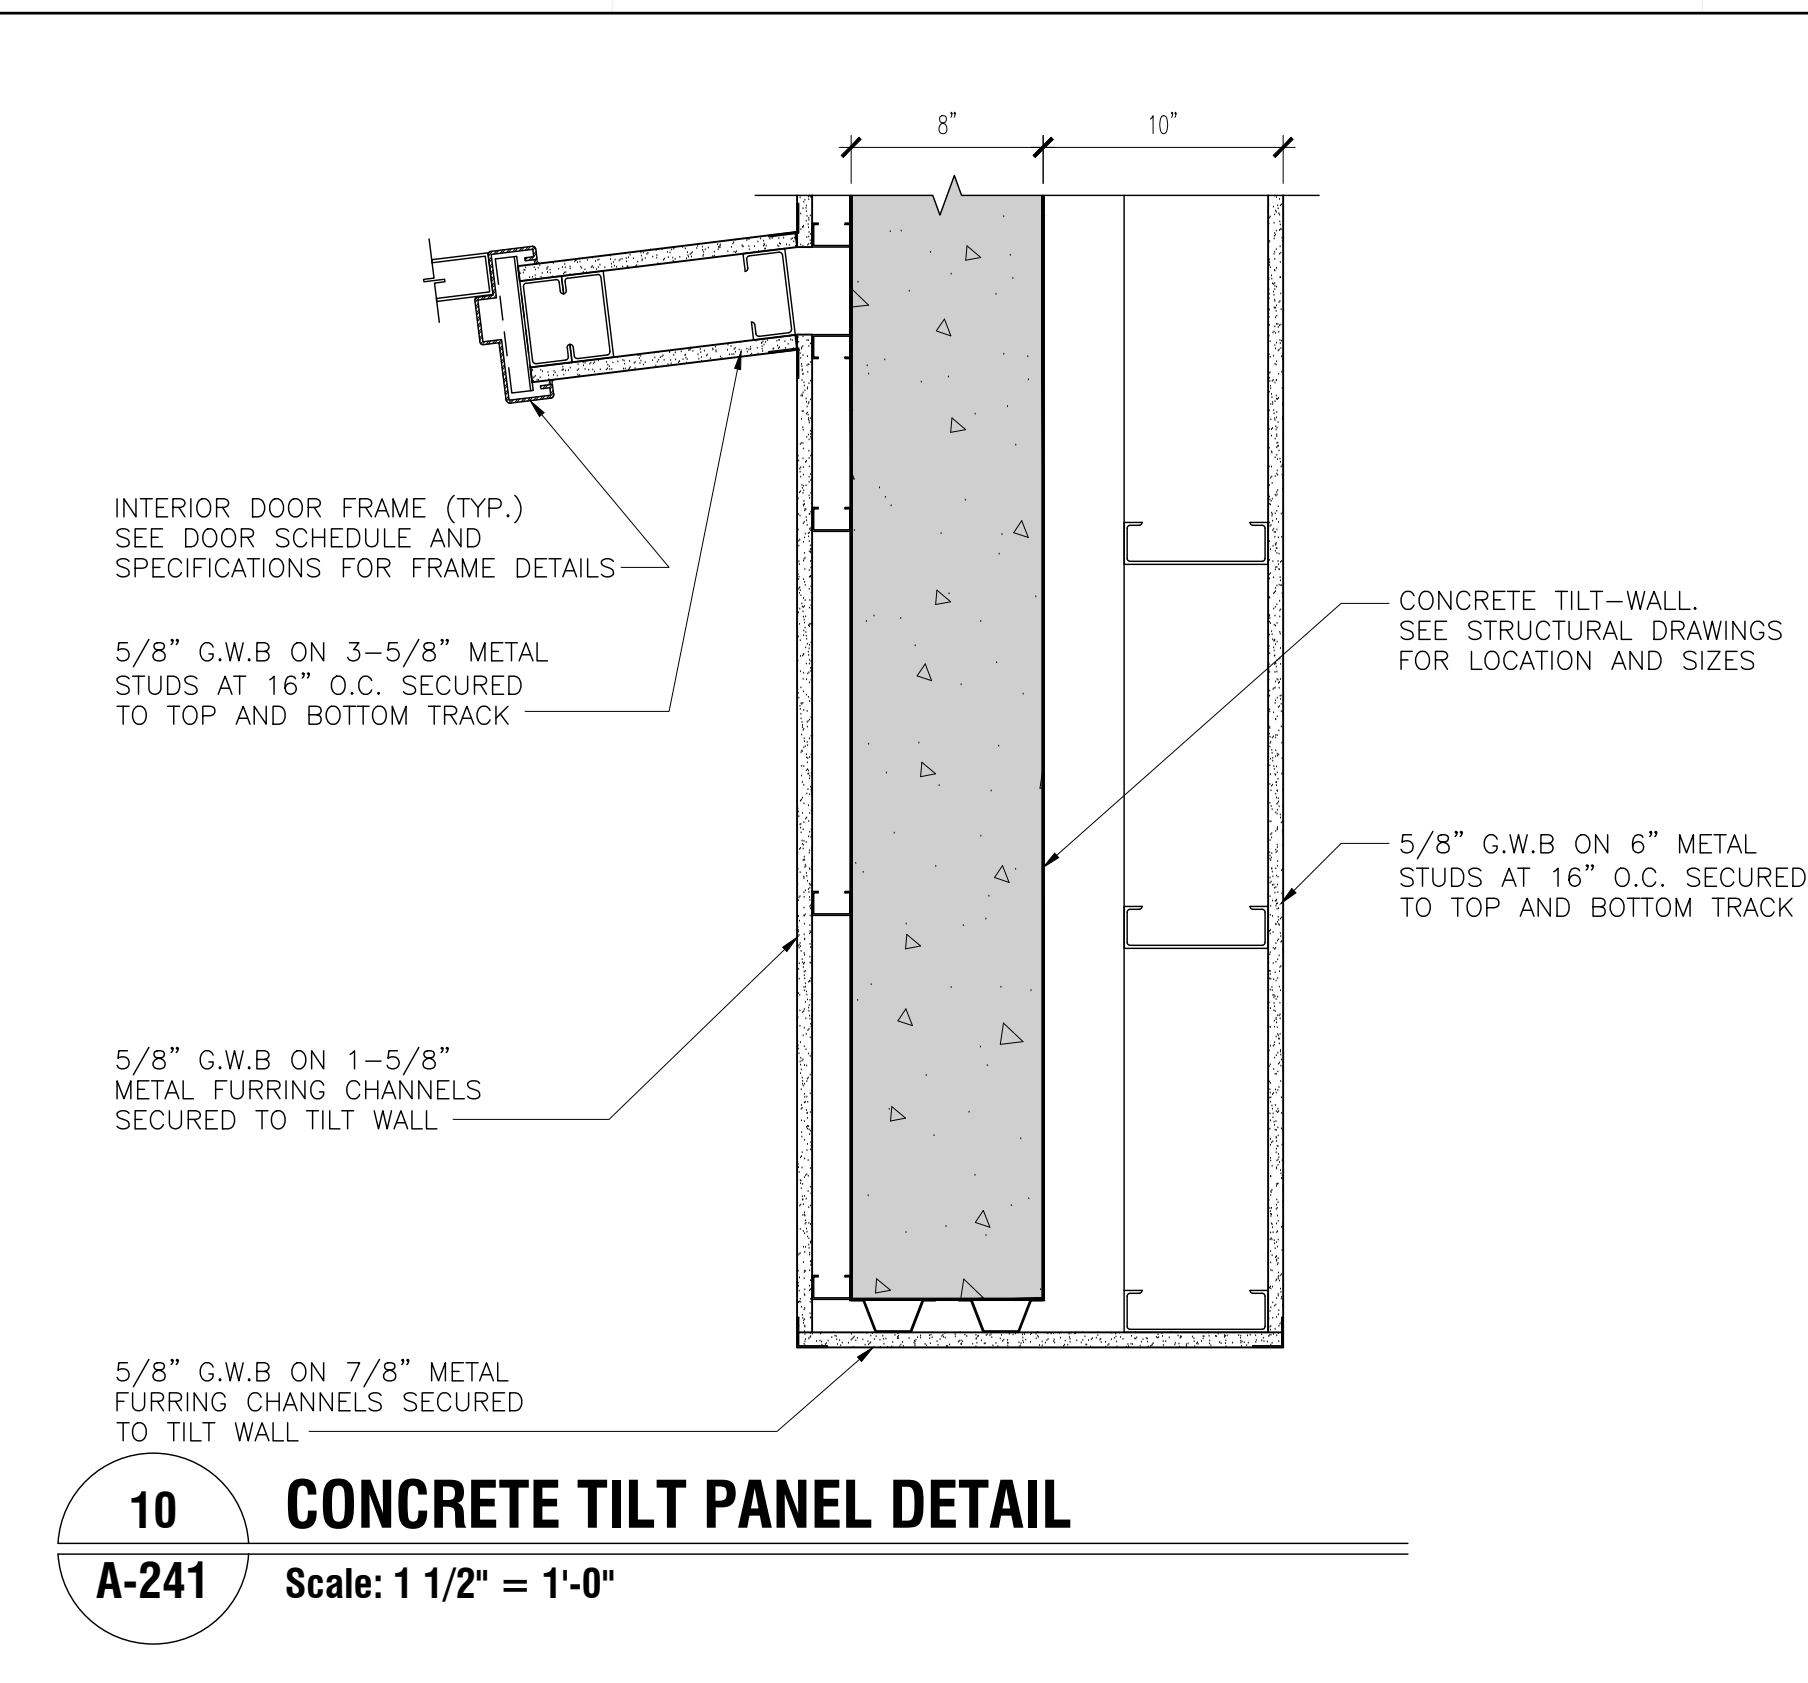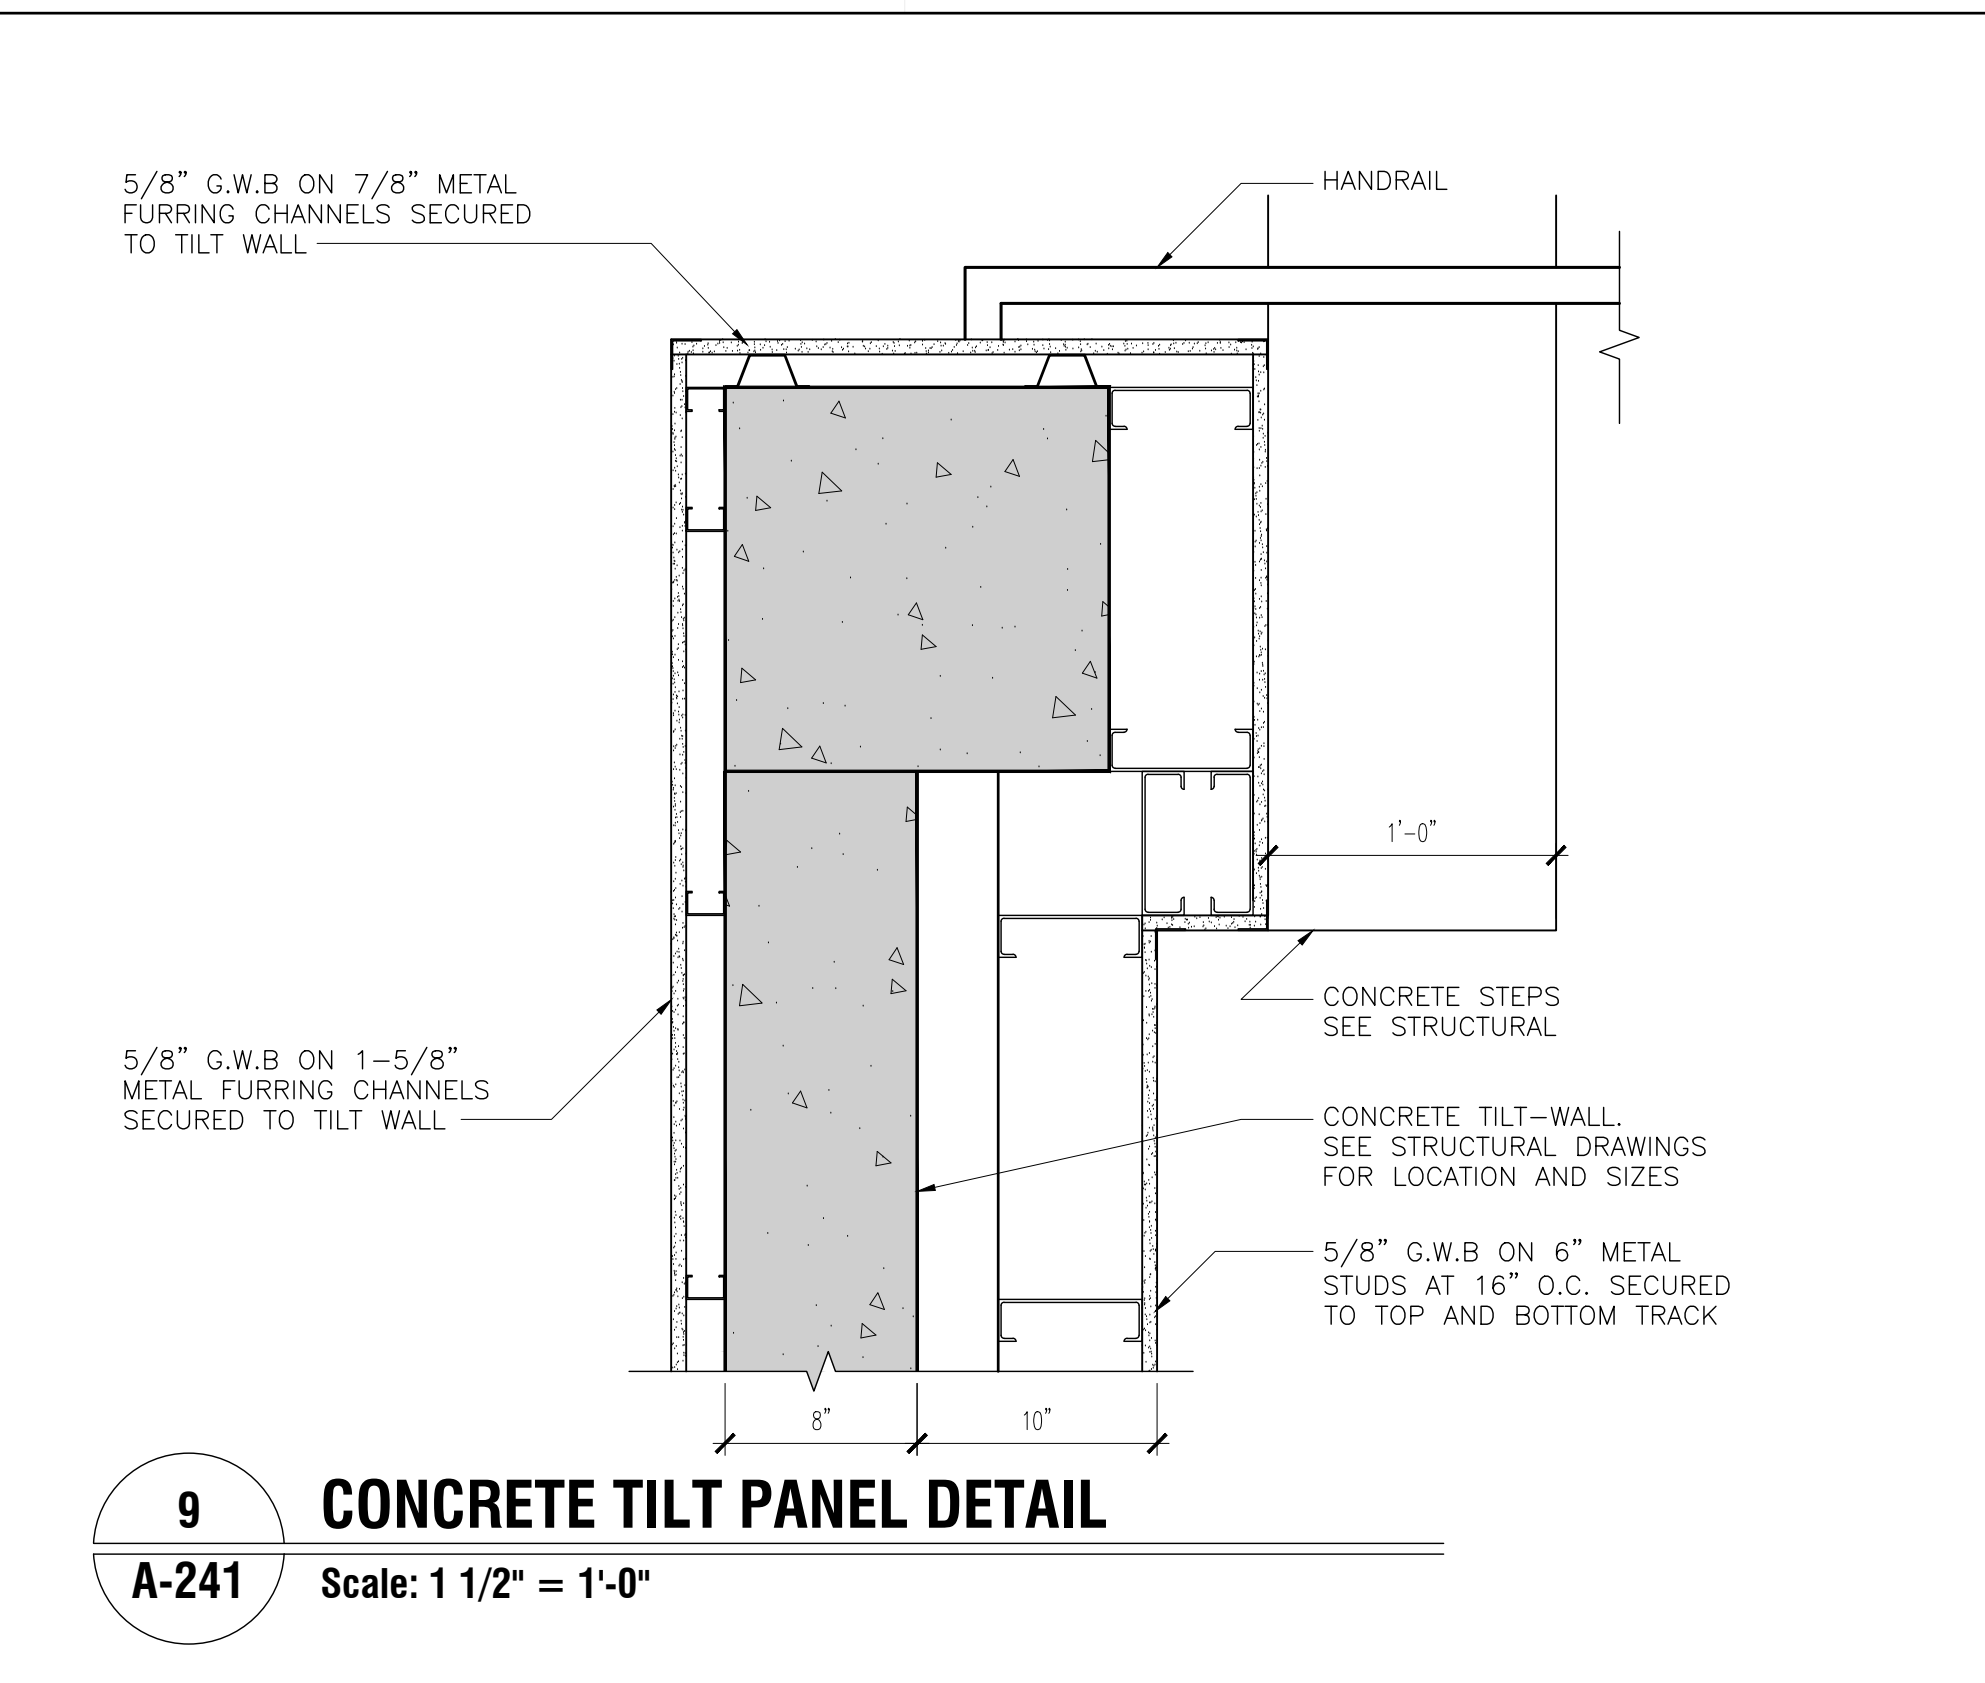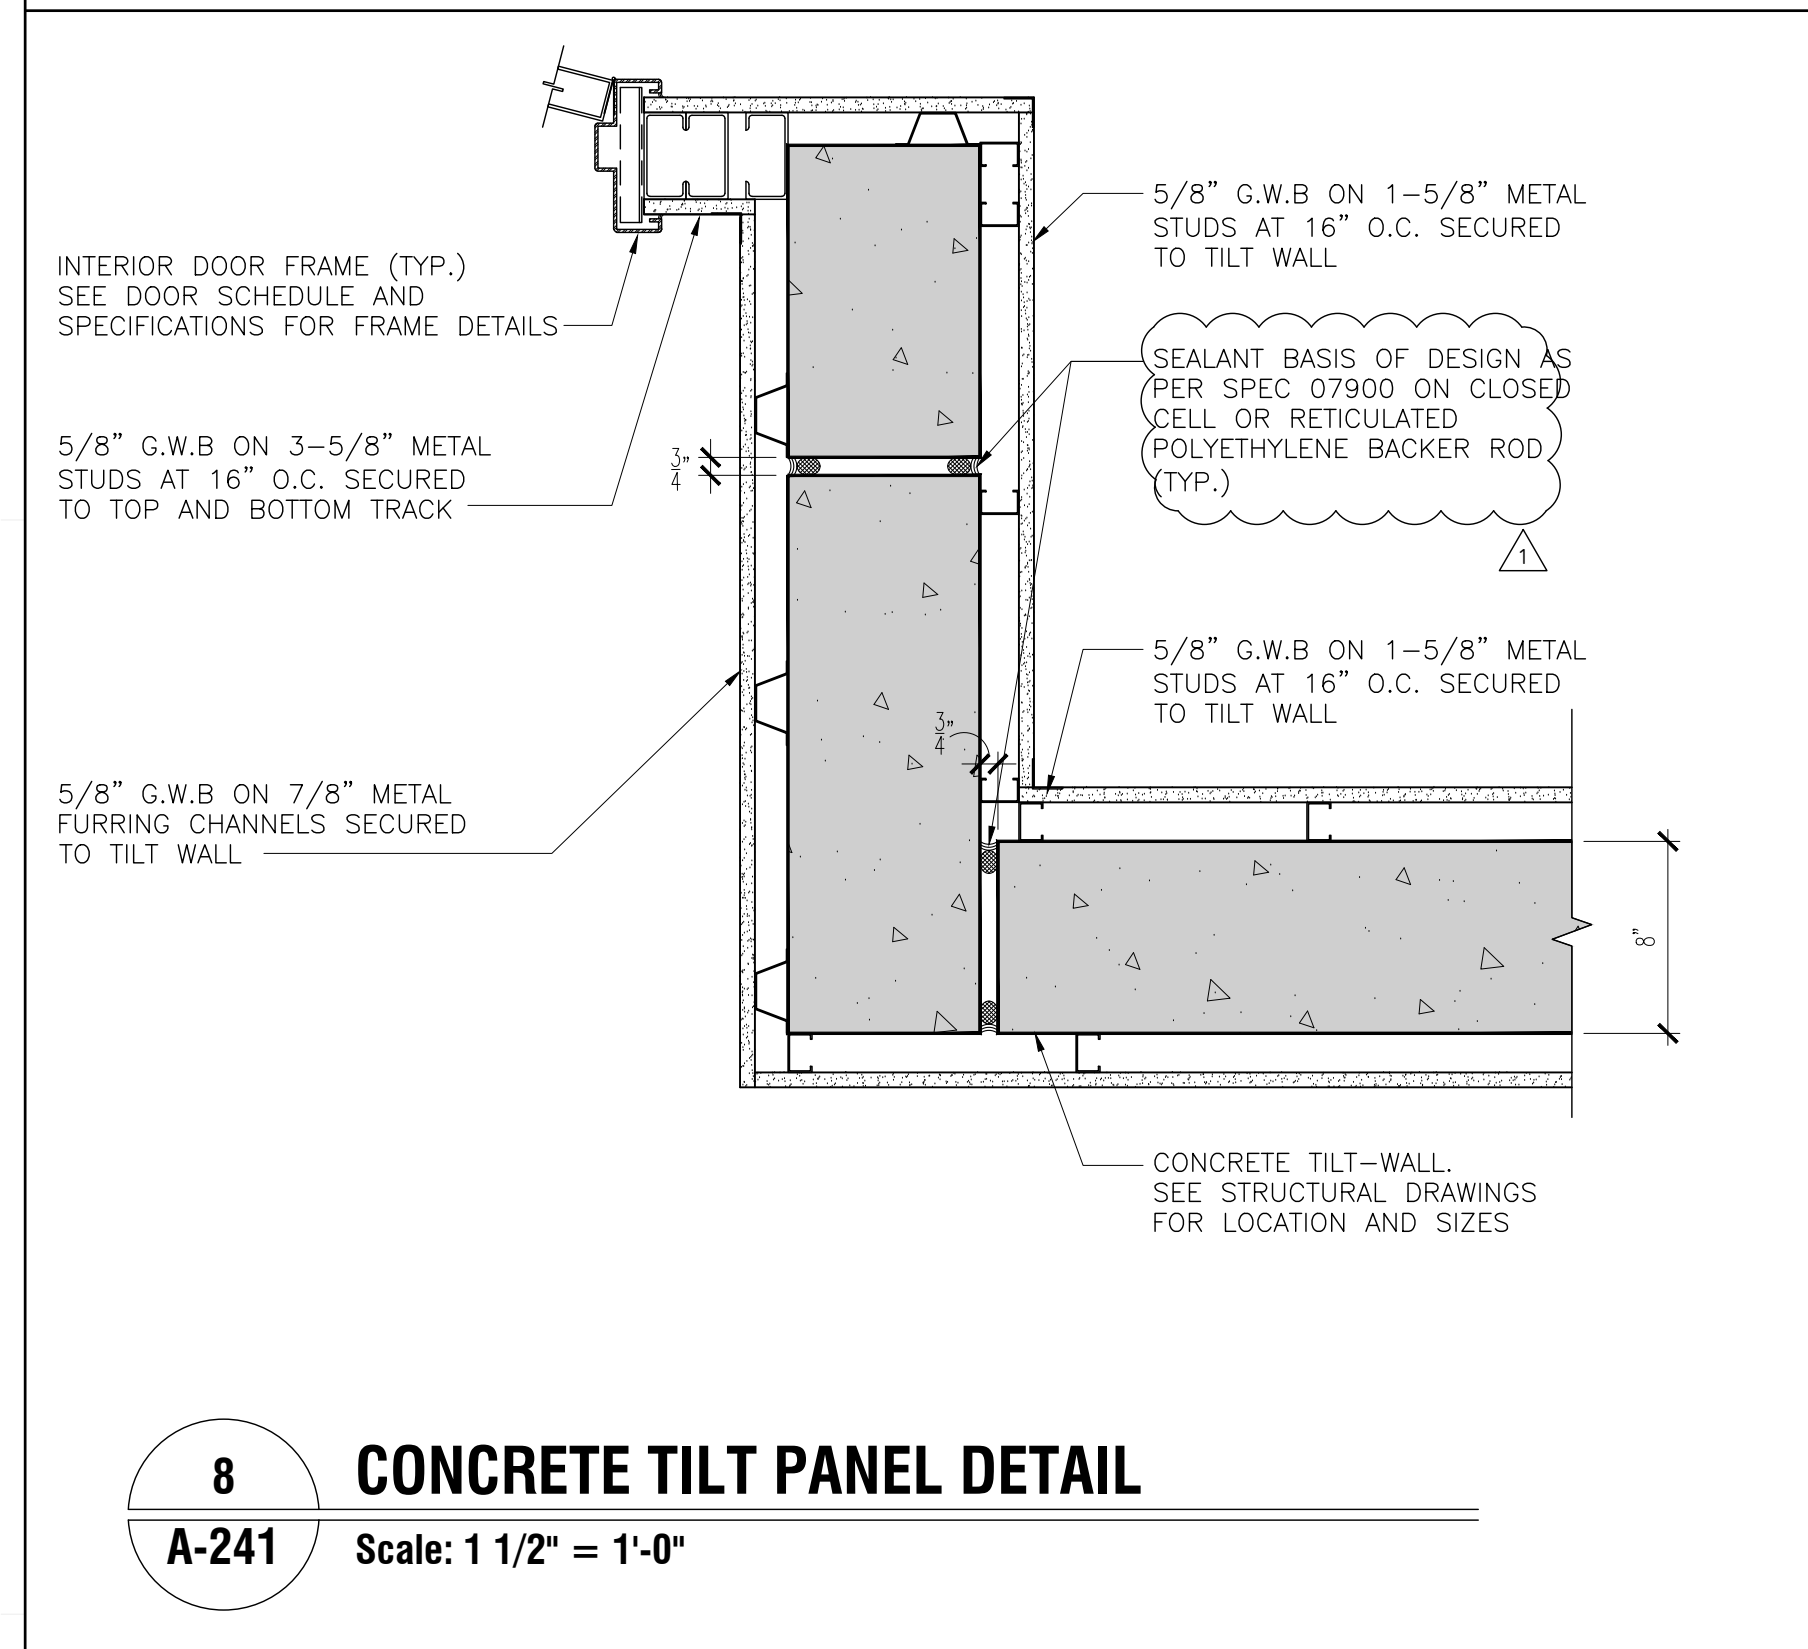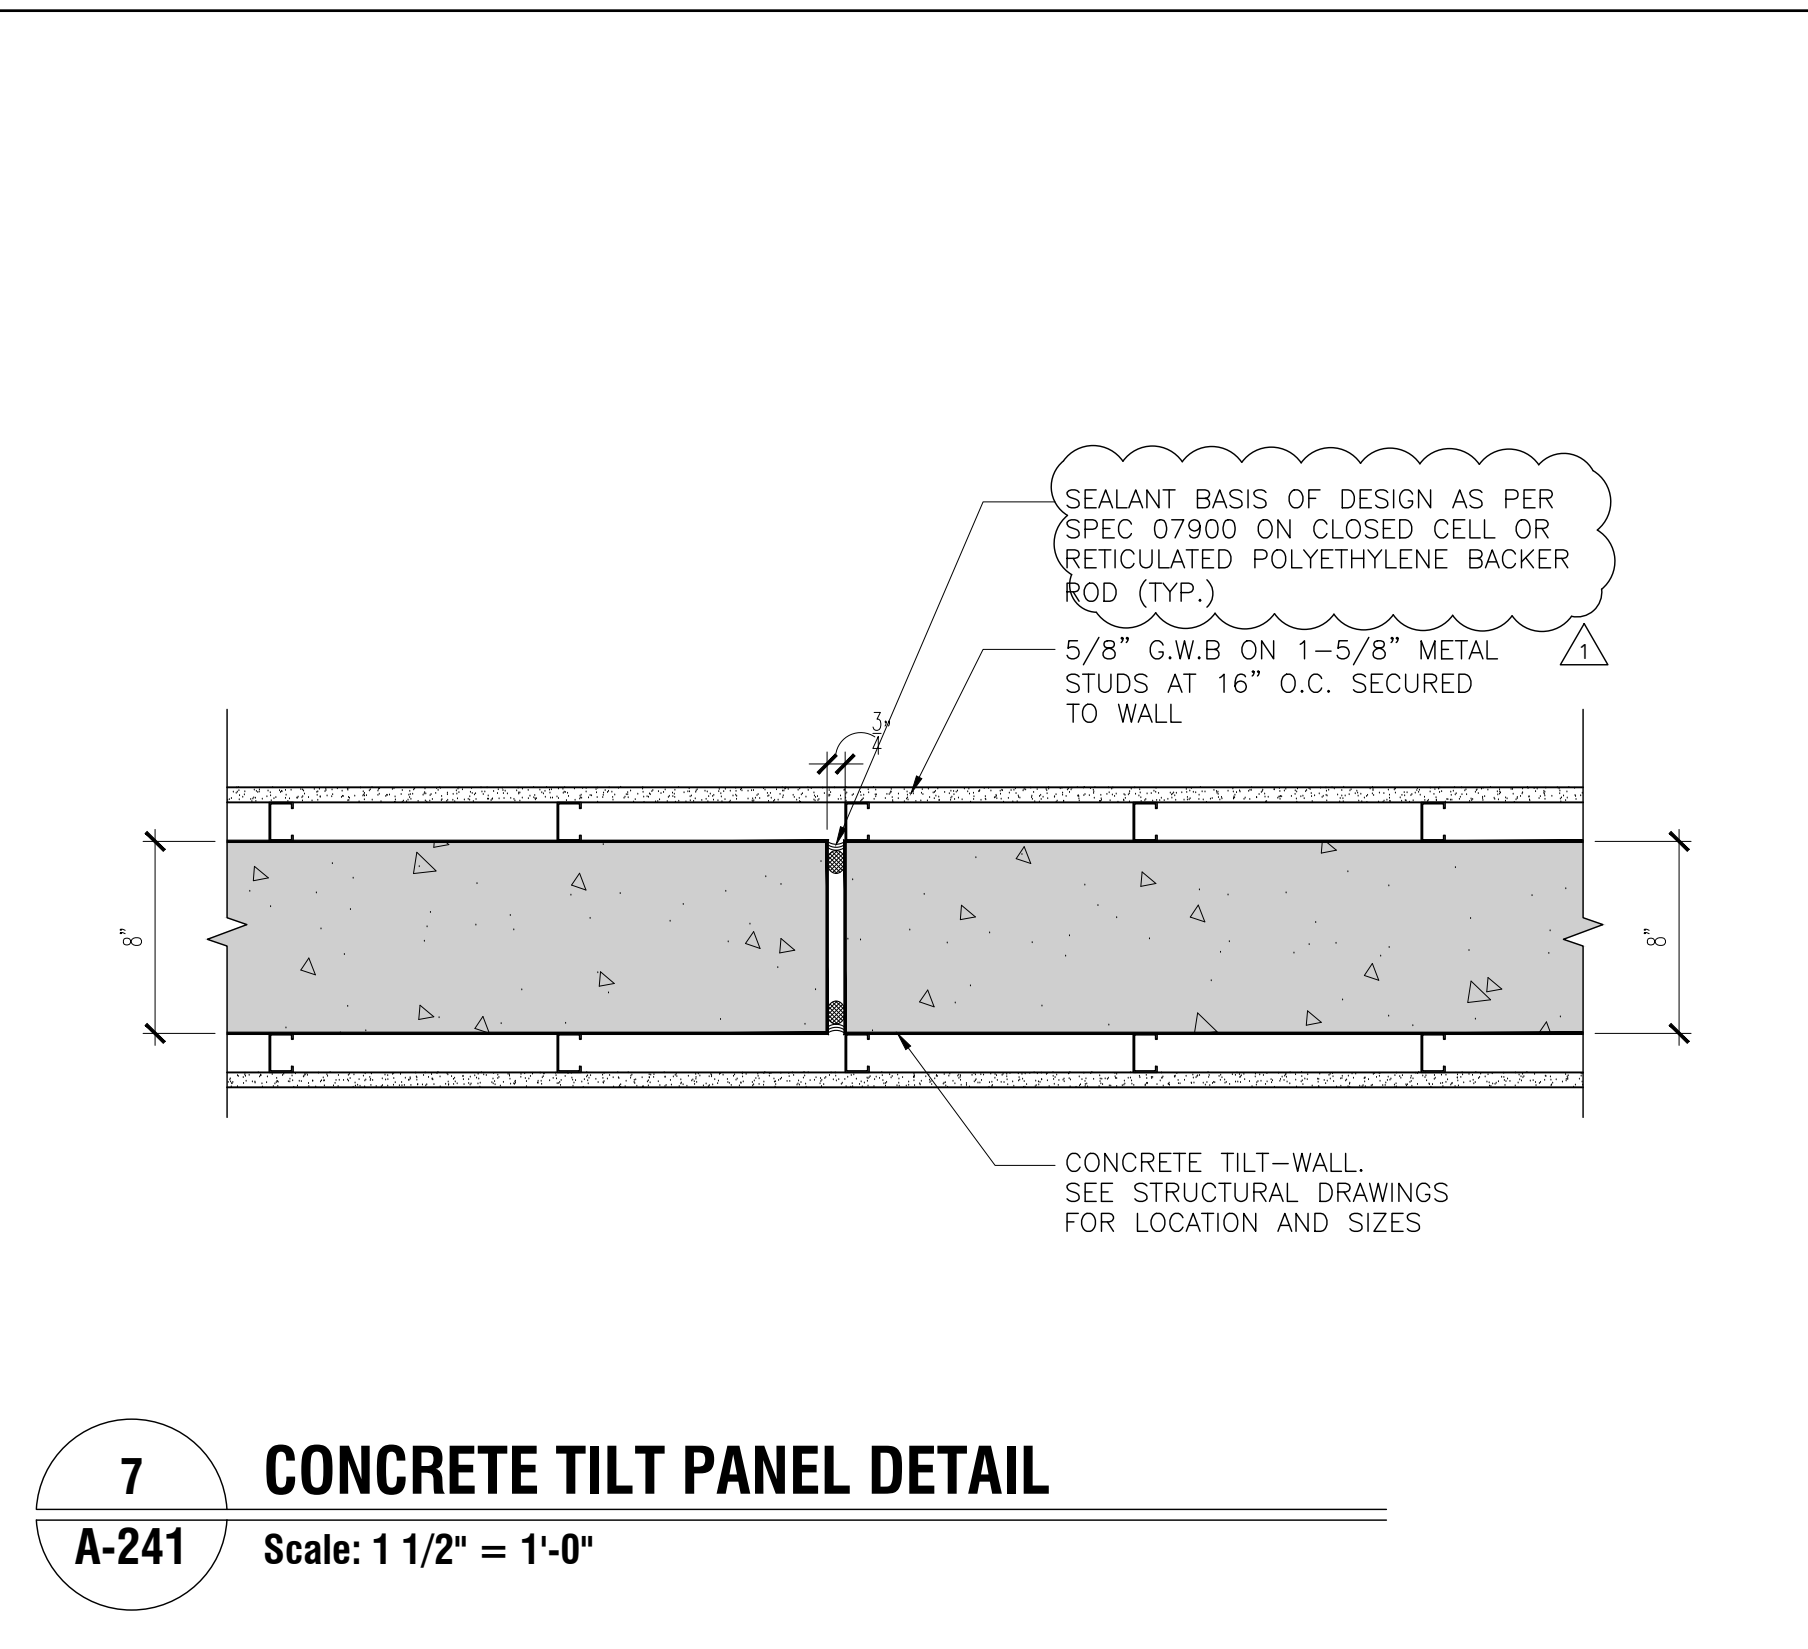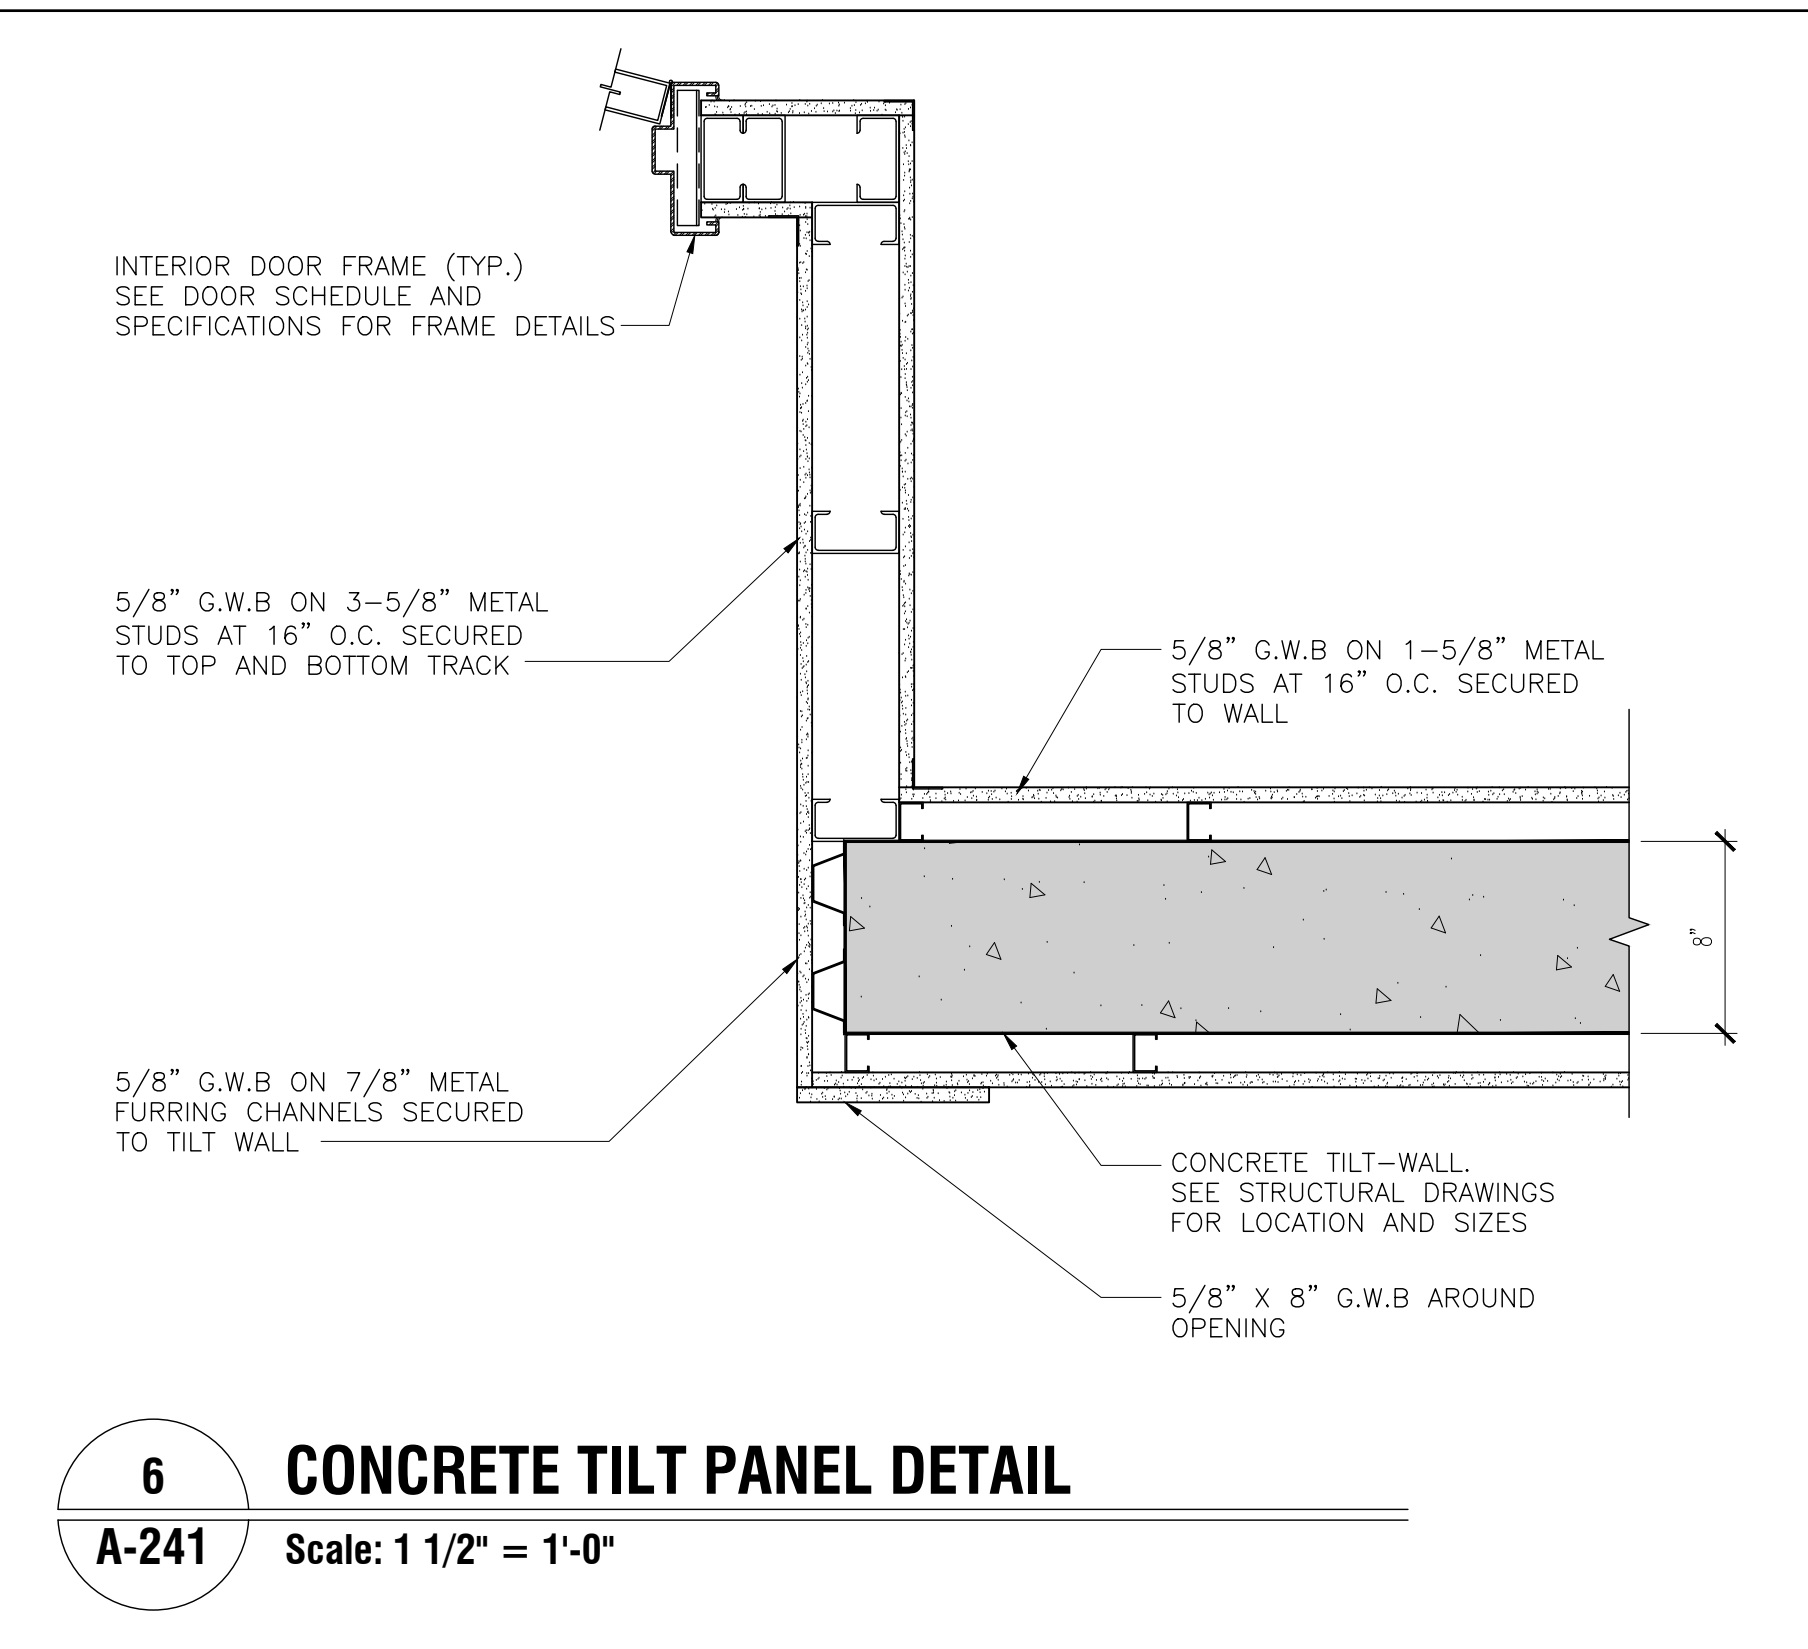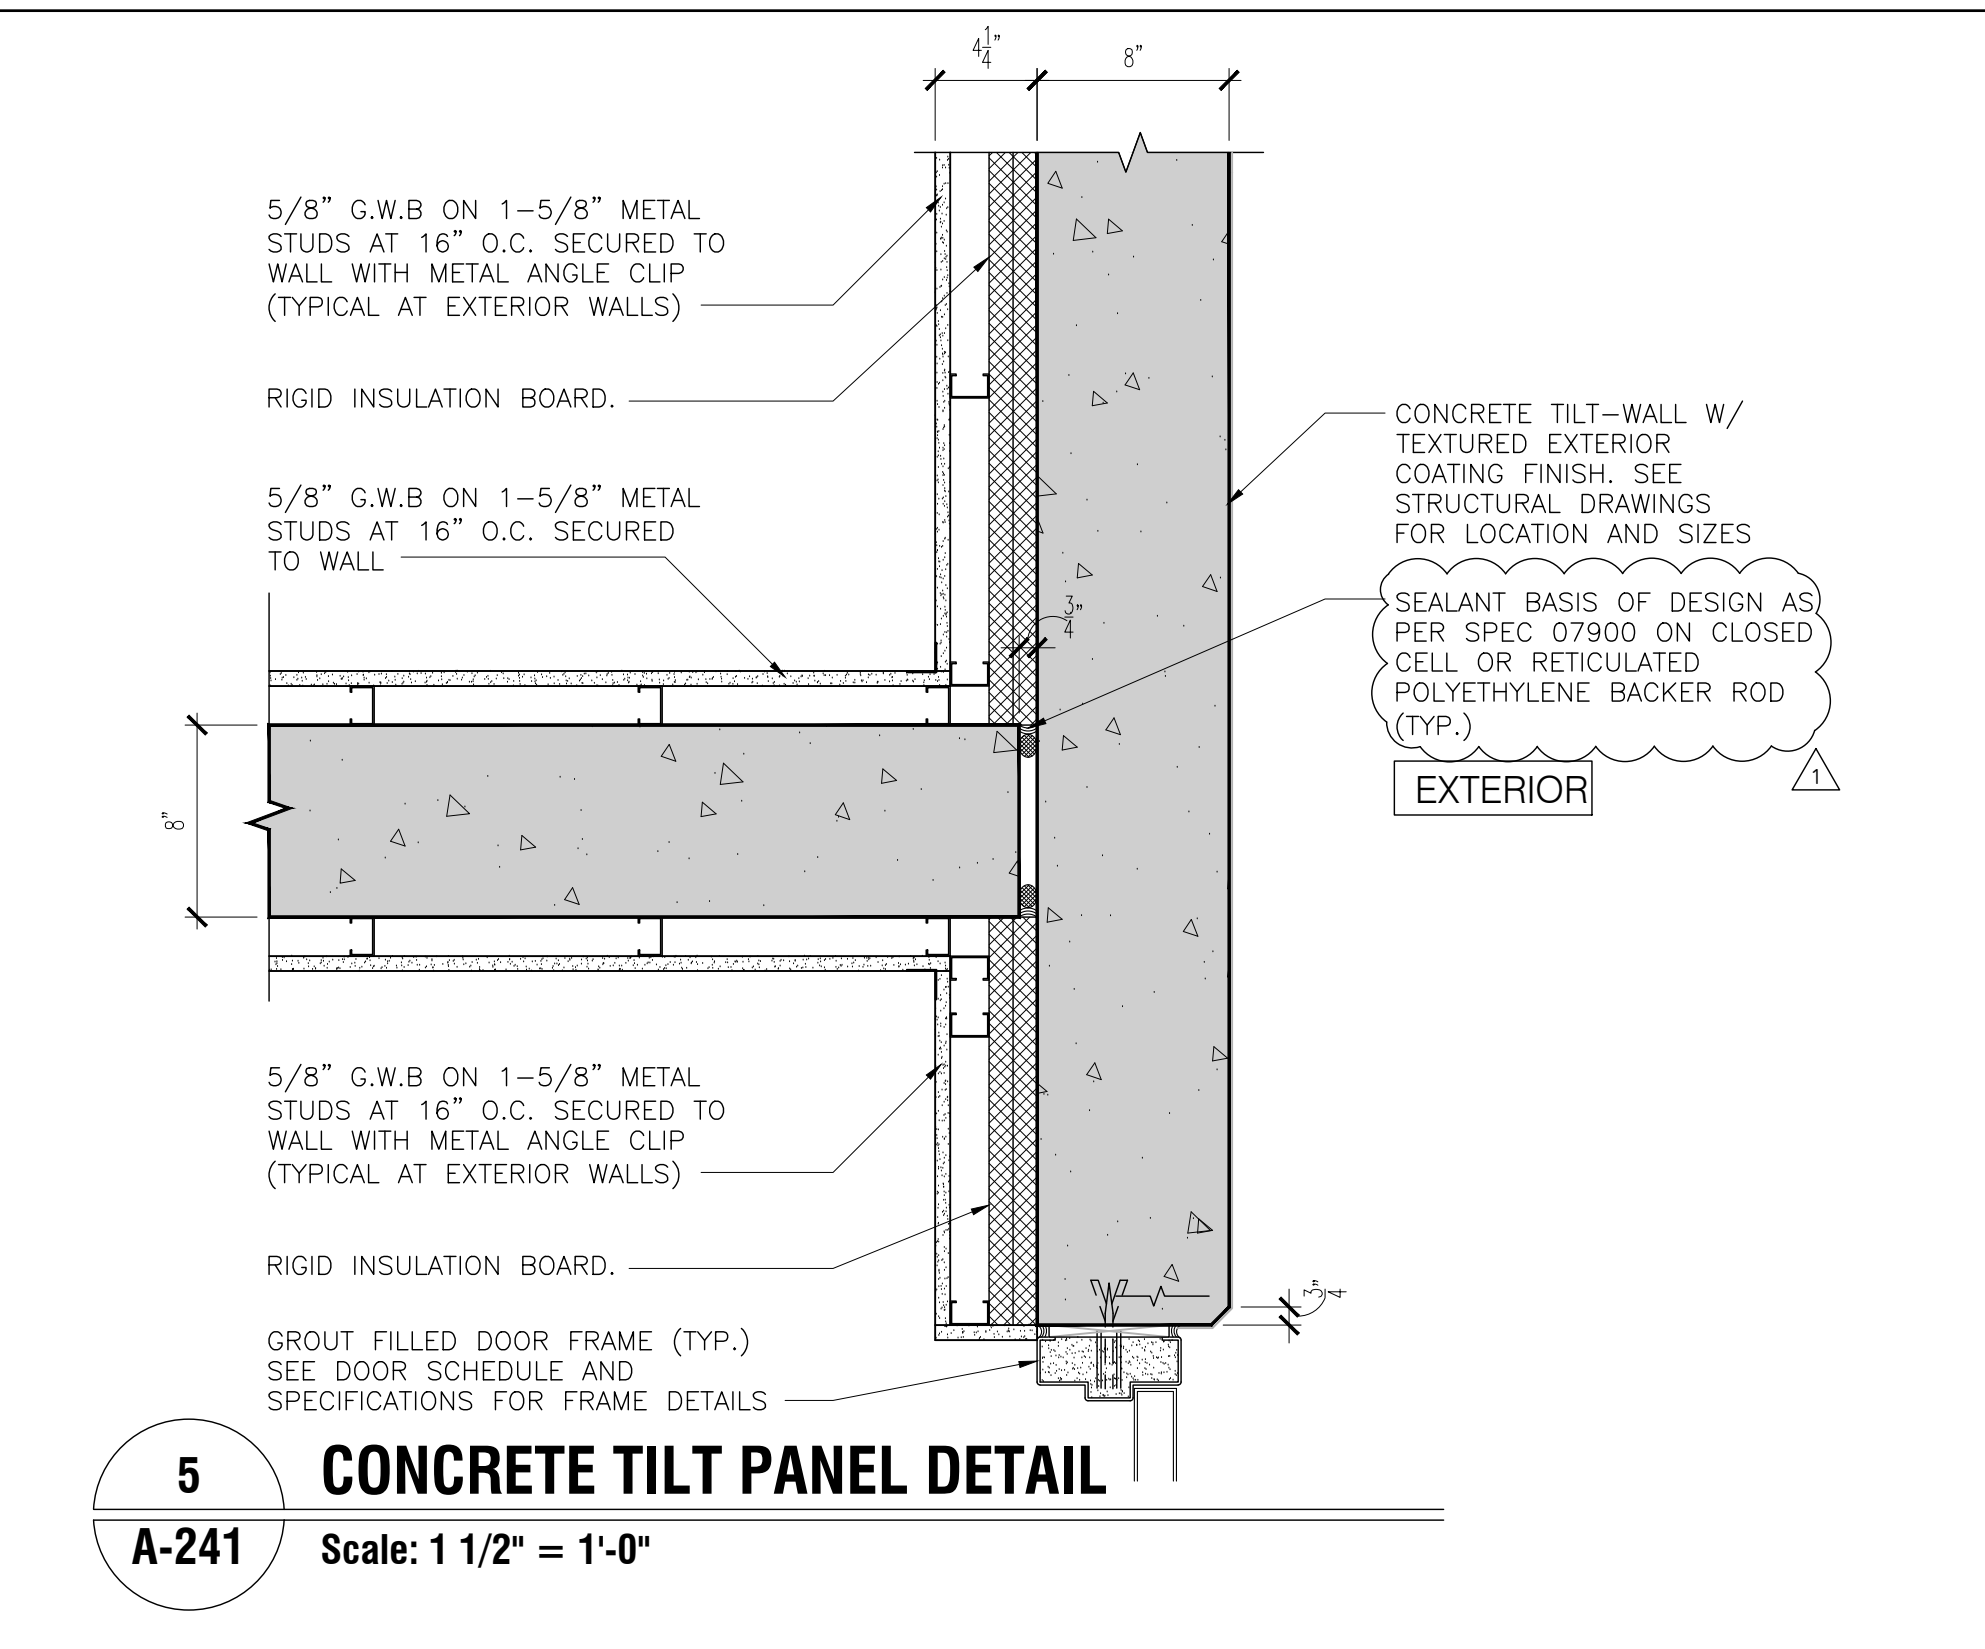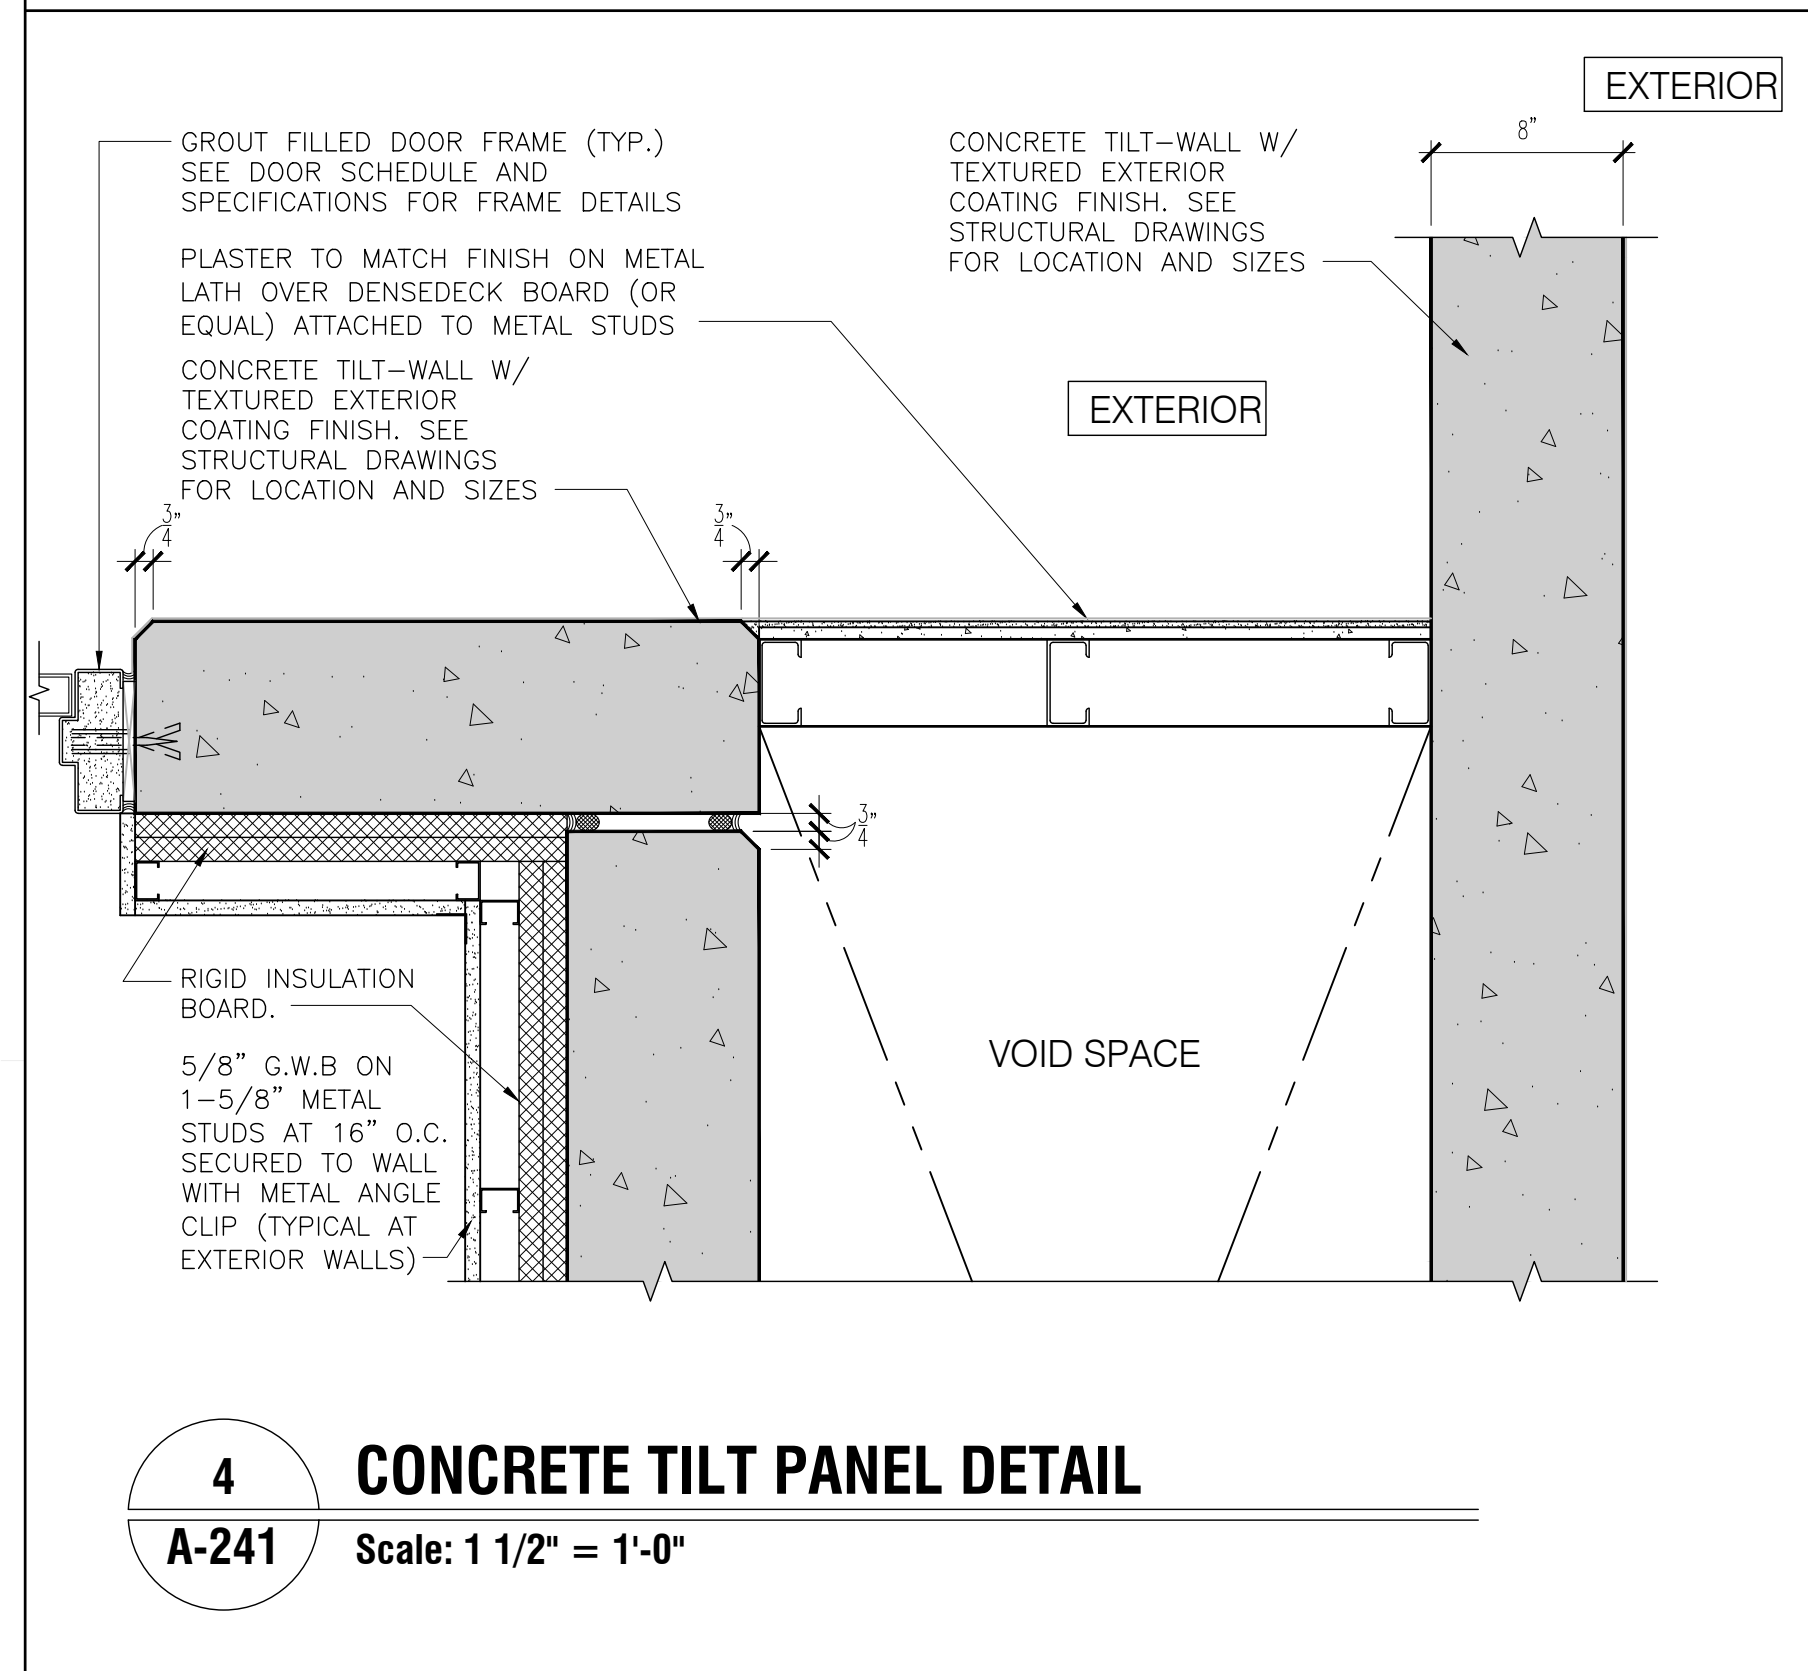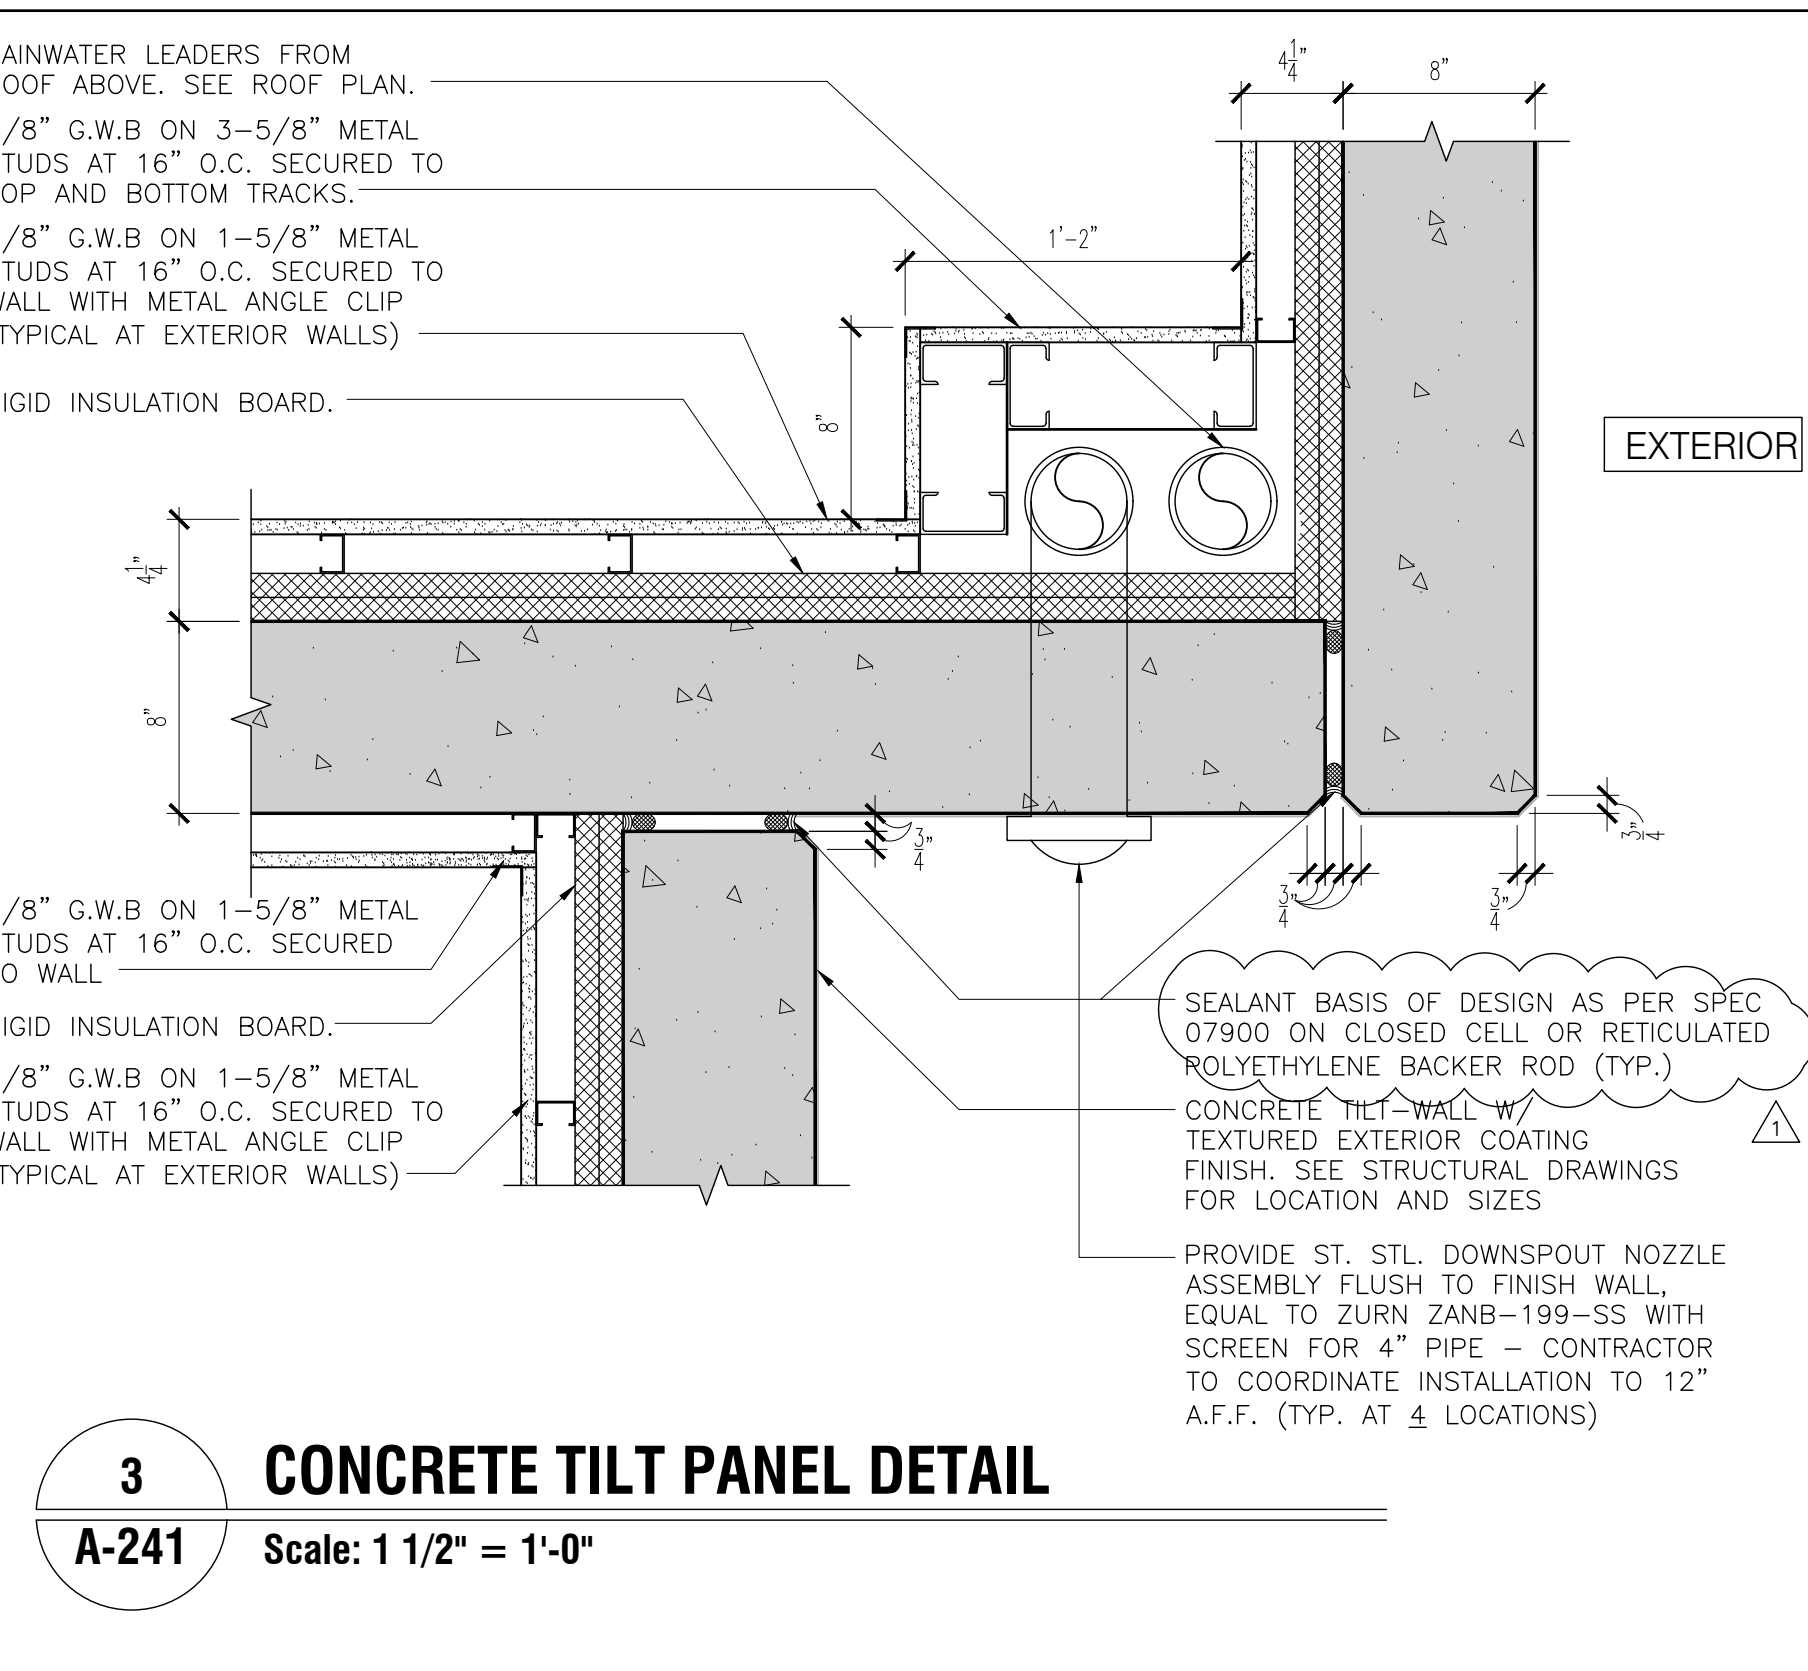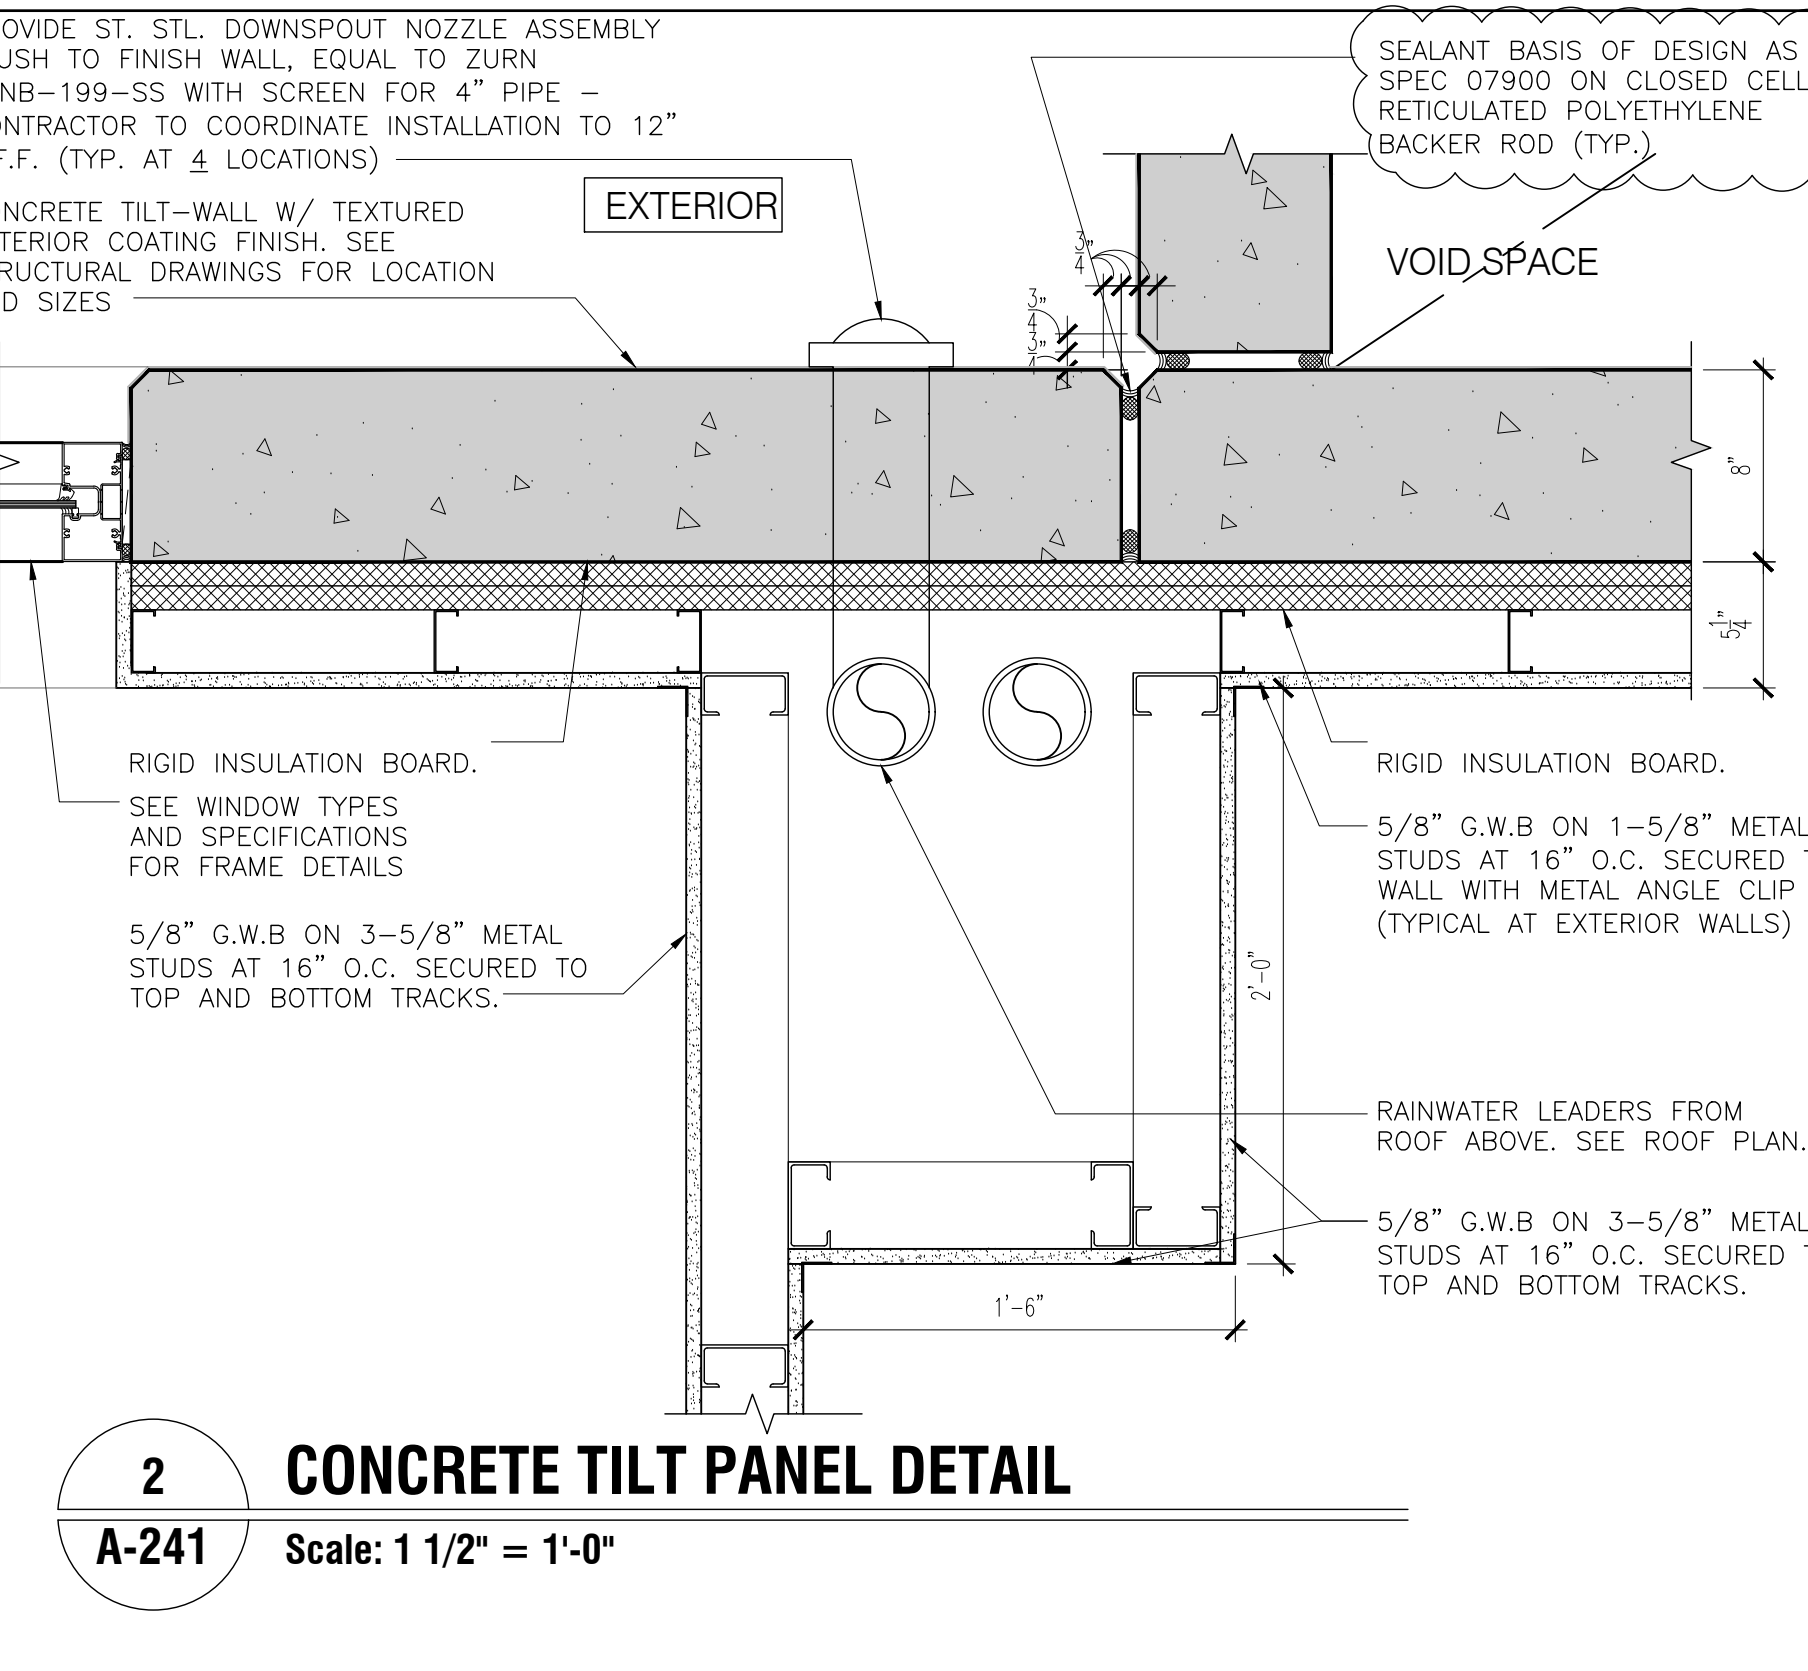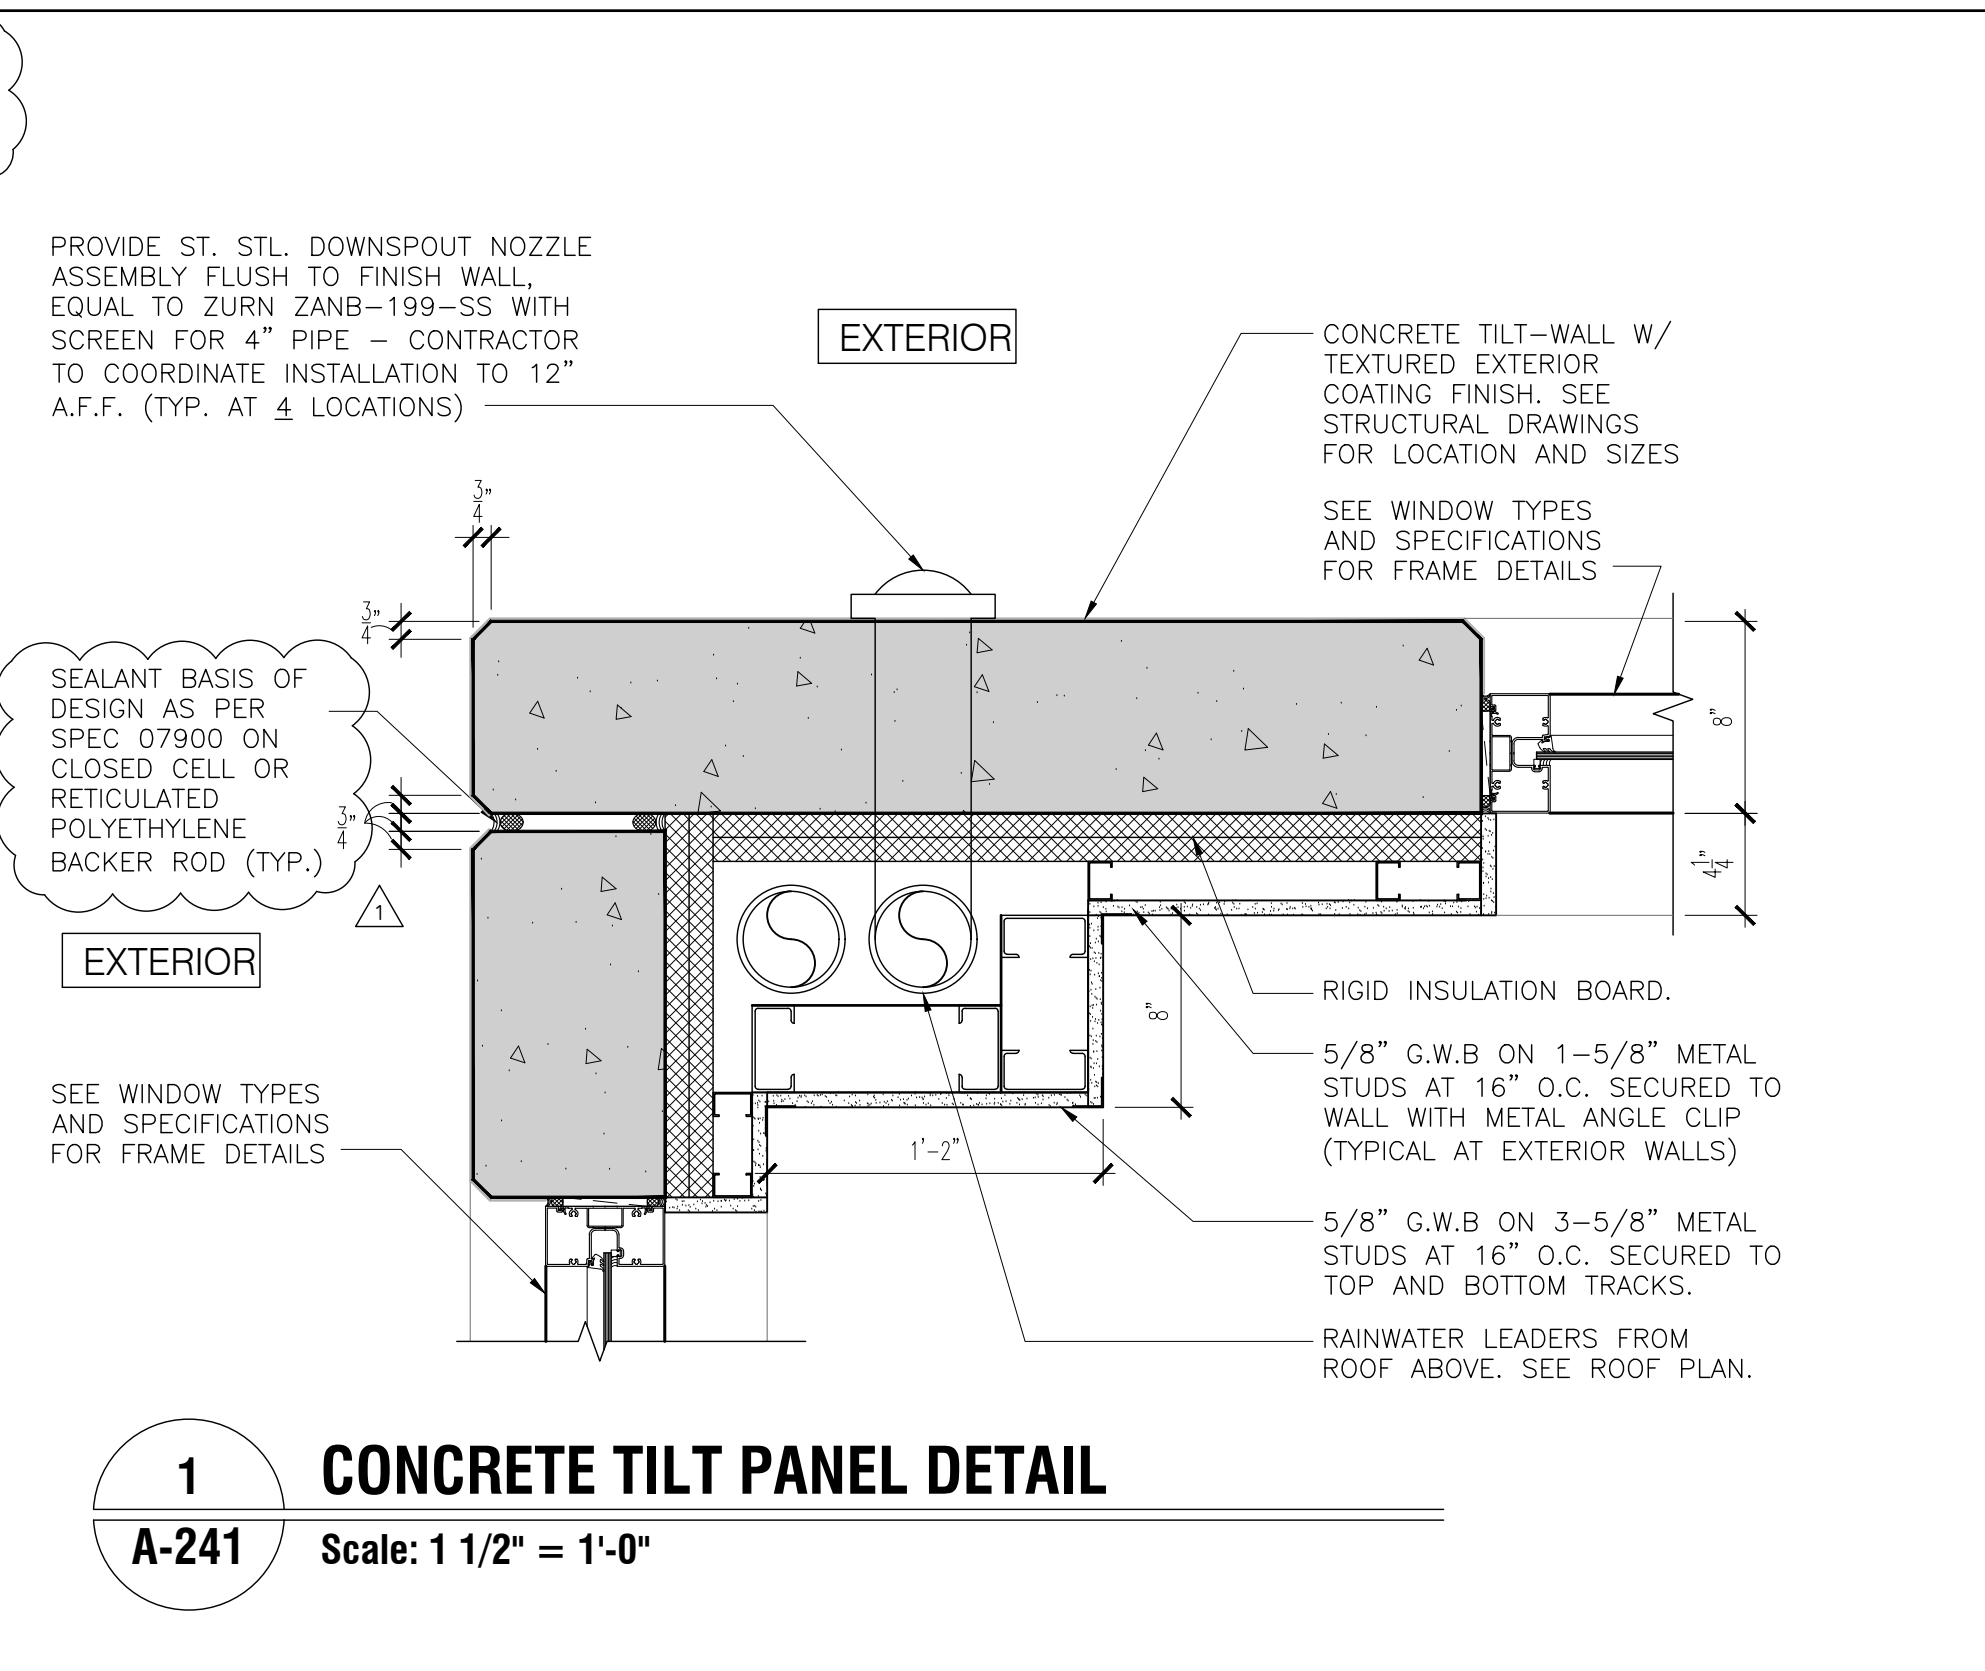

12

NOT USED

A-250

10

ENLARGED PLAN DETAIL - DRINKING FOUNTAIN ALCOVE

A-250

Scale: 3/4" = 1'-0"

9

CONCRETE TILT PANEL - PLAN DETAIL

A-250

Scale: 1 1/2" = 1'-0"

8

MASONRY VENEER
CONCRETE TILT PANEL - SECTION DETAIL (TYP.)

A-250

Scale: 1 1/2" = 1'-0"

6

ENLARGED PLAN DETAIL - DRINKING FOUNTAIN

A-250

Scale: 3/4" = 1'-0"

4

DOUBLE DOOR ALCOVE

A-250

Scale: 3/4" = 1'-0"

2

FIRE EXTINGUISHER DETAIL

A-250

Scale: 1/2" = 1'-0"

7

MASONRY VENEER
CONCRETE TILT PANEL - SECTION DETAIL (TYP.)

A-250

Scale: 1 1/2" = 1'-0"

5

ENLARGED PLAN DETAIL - DRINKING FOUNTAIN

A-250

Scale: 3/4" = 1'-0"

3

ENLARGED PLAN DETAIL - DRINKING FOUNTAIN ALCOVE

A-250

Scale: 3/4" = 1'-0"

1

ENLARGED PLAN DETAIL - TYPICAL ENTRY ALCOVE

A-250

Scale: 1/2" = 1'-0"

NEW ELEMENTARY SCHOOL (K-5)

VENETIAN PARC WEST

SOUTHWEST 157th AVENUE and 174th STREET
MIAMI, FL. 33187
MDCPS PROJECT No. 01892600

KEY PLAN

CONSULTANT INFO

REVISIONS

PROJECT NO. 1906

SHEET: A-250

RODRIGUEZ ARCHITECTS INCORPORATED

2121 PONCE DE LEON BLVD. STE 1010
CORAL GABLES, FL. 33134
TEL: (305) 448-3373
FAX: (305) 448-3374
A A C — 0 0 1 9 3 3

RAI

CONSULTANT INFO

REVISIONS

PROJECT NO. 1906


SHEET: A-250

REFL. CEILING PLAN LEGEND

1X4 FLUORESCENT LIGHT FIXTURE	1X4 EMERGENCY FLUORESCENT LIGHT FIXTURE
2X4 FLUORESCENT LIGHT FIXTURE	2X4 EMERGENCY FLUORESCENT LIGHT FIXTURE
2X2 INDIRECT FLUORESCENT LIGHT FIXTURE	2X2 EMERGENCY INDIRECT FLUORESCENT LIGHT FIXTURE
FLUORESCENT STRIP LIGHT FIXTURE	EMERGENCY FLUORESCENT STRIP LIGHT FIXTURE
WALL MTD. FLUORESCENT STRIP LIGHT FIXTURE	EMERGENCY WALL MTD. FLUORESCENT STRIP LIGHT FIXTURE
PENDANT LIGHT FIXTURE	CEILING MOUNTED TRACK LIGHTS
WALL MTD. LIGHT FIXTURE	WALL MOUNTED WALL WASHER
RECESSED HIGH-HAT LIGHT FIXTURE	RECESSED EMERGENCY HIGH HAT LIGHT FIXTURE
EXIT SIGN	EMER. WALL MOUNTED LIGHT FIXTURE
EXIT SIGN (WALL MOUNT)	A/C AIR RETURN GRILL (SEE MECHANICAL DRAWINGS FOR SIZE, OUTPUT, ETC.)
A/C SUPPLY GRILL (SEE MECHANICAL DRAWINGS FOR SIZE, OUTPUT, ETC.)	SECURITY CAMERA LOCATION (SEE ELECTRICAL DRAWINGS FOR SIZE, CONDUIT, ETC.)
2'X4' PYRAMIDAL ACOUSTICAL DIFFUSER PANEL	EMERGENCY LIGHT FIXTURE
INCANDESCENT OR H.I.D. LIGHT FIXTURE (SEE REFL. LT. FINISH SCH.)	CEILING PROJECTOR (NIC) (SEE ENLARGEMENT PLAN A-700'S FOR ACTUAL LOCATION, DIRECTION, ETC.)
EXHAUST FAN	CEILING SPEAKER
RETURN OR OUTSIDE AIR DUCT	WOOD MOLDING AND DENTILS (AT FULL PERIMETER)
CEILING FAN	2' X 4' ACOUSTICAL LAY-IN CEILING
	2' X 2' ACOUSTICAL LAY-IN CEILING
	2' X 2' ACOUSTICAL LAY-IN CEILING WASHABLE SURFACE
	EXPOSED STRUCTURE
	GYPSUM WALL BOARD CEILING OR SOFFIT AREA
	2 COATS CEMENT PLASTER ON MTL. LATH - SEE STRUCT. DWGS. FRAMING/SUPPORT
	2 COATS CEMENT PLASTER ON CEMENT BOARD
	EPOXY PAINT ON MOISTURE RESISTANT GYPSUM BOARD


REFL. CEILING GENERAL NOTES

- DIMENSIONS NOTED IN EACH AREA DESIGNATE CEILING HEIGHT ABOVE FINISH FLOOR.
- SEE PLUMB., ELEC. AND FIRE PROT. DRAWINGS FOR LOCATIONS OF SPRINKLER HEADS AND LIGHT FIXTURES IN EXPOSED CEILING AREAS. CONTRACTOR TO COORDINATE FINAL FIRE PROTECTION DRAWINGS WITH ARCHITECT FOR LAYOUT CONFIRMATION.
- ALL SYSTEMS FIXTURES ARE TO BE LOCATED CENTER OF TILE (TYP.).
- CONTRACTOR TO COORDINATE ALL DISCIPLINES TO ENSURE CLEARANCES FOR ALL DUCTWORK, EQUIPMENT, FIXTURES, PIPES, CONDUITS, AND CEILING SYSTEMS NECESSARY TO MAINTAIN CEILING ELEVATIONS NOTED.
- ALL EXPOSED CEILING AREAS TO BE FULLY PAINTED. COORDINATE ALL COLOR SELECTIONS WITH ARCHITECT. SYSTEMS COLORS TO BE CUSTOM. (WHERE DUCTWORK IS EXPOSED IN OCCUPIED SPACES - DUCTWORK SHALL BE ROUND DOUBLE WALL METAL.)
- EXPOSED SYSTEMS AREAS TO BE COORDINATED AND LOCATED IN A CLEAN AND ORGANIZED FASHION. ALL ELECTRICAL CONDUIT AND JUNCTION BOXES TO BE MOUNTED AT UNDERSIDE OF DECK (NO RUNS OR TERMINATIONS AT JOISTS).
- ALL WALL PENETRATIONS TO EXPOSED CEILING AREAS TO BE CONSTRUCTED WITH APPROVED UL ASSEMBLY PROTECTION, PER WALL RATING REQUIREMENTS.
- CONTRACTOR TO COORDINATE ALL DUCT LOCATIONS WITH ALL OTHER TRADES. ARCHITECT TO REVIEW AND HAVE FINAL APPROVAL FOR ALL EXPOSED CEILING AREAS.
- ALL SECURITY CAMERA LOCATIONS TO HAVE JUNCTION BOX WITH COVER AND CONDUIT TAIL (WITH PULL STRING) TO ABOVE CEILING AREA (ACCESSIBLE) AS DESIGNATED BY OWNER - SEE ELECTRICAL DRAWINGS. ALL EXTERIOR LOCATIONS TO HAVE DAMP-PROOF BOX.
- ALL CLASSROOMS, LABS AND TEACHING SPACES TO BE PROVIDED WITH INFRASTRUCTURE PROVISION FOR FUTURE FULL AUDIO ENHANCEMENT SYSTEM.
- ALL CEILING RECESSED OR MOUNTED PROJECTION SCREENS ARE TO BE MOTORIZED. CONTRACTOR TO PROVIDE REQUIRED ELECTRICAL (AND DATA IF REQUIRED) SYSTEMS CONNECTIONS FOR COMPLETE SYSTEM INSTALLATION.
- ALL DECORATIVE LIGHT FIXTURES ARE TO BE COORDINATED WITH ARCHITECT FOR FINAL SELECTION OF FIXTURE, FINISH AND LOCATION.
- ALL OCCUPIED SPACES ARE TO HAVE OCCUPANCY SENSORS FOR ADDITIONAL LIGHT CONTROLS.
- REFER TO SECTIONS, WALL SECTIONS AND ROOF DETAILS FOR ALL OVERHANG AND DENTIL DETAILS.
- CONTRACTOR TO COORDINATE ALL LOCATIONS FOR INTERIOR AND EXTERIOR STUCCO AND PLASTER FINISH REVEALS WITH ARCHITECT. CONTRACTOR TO PROVIDE SHOP DRAWING LAYOUT FOR ALL REQUIRED REVEALS AND CONTROL JOINTS.
- ALL PAINT FINISH HARD SOFFITS ARE TO BE PAINTED WHITE UNLESS OTHERWISE NOTED.
- ALL SYSTEMS ARE TO BE LOCATED AND INSTALLED IN AN ORGANIZED NATURE FOR ALL CEILING AREAS. ANY CONFLICTS ARE TO BE NOTED TO ARCHITECT PRIOR TO INSTALLATION.
- FINAL ELEVATIONS OF LIGHT FIXTURES (PENDENT AND INDIRECT) ARE TO BE COORDINATED WITH ARCHITECT AT TIME OF SHOP DRAWING AND PRODUCT REVIEW SUBMISSION.
- ALL FIRE PROTECTION SPRINKLERS ARE TO BE SEMI-RECESSED TYPE WITH FINISH TO BE COORDINATED WITH ARCHITECT.

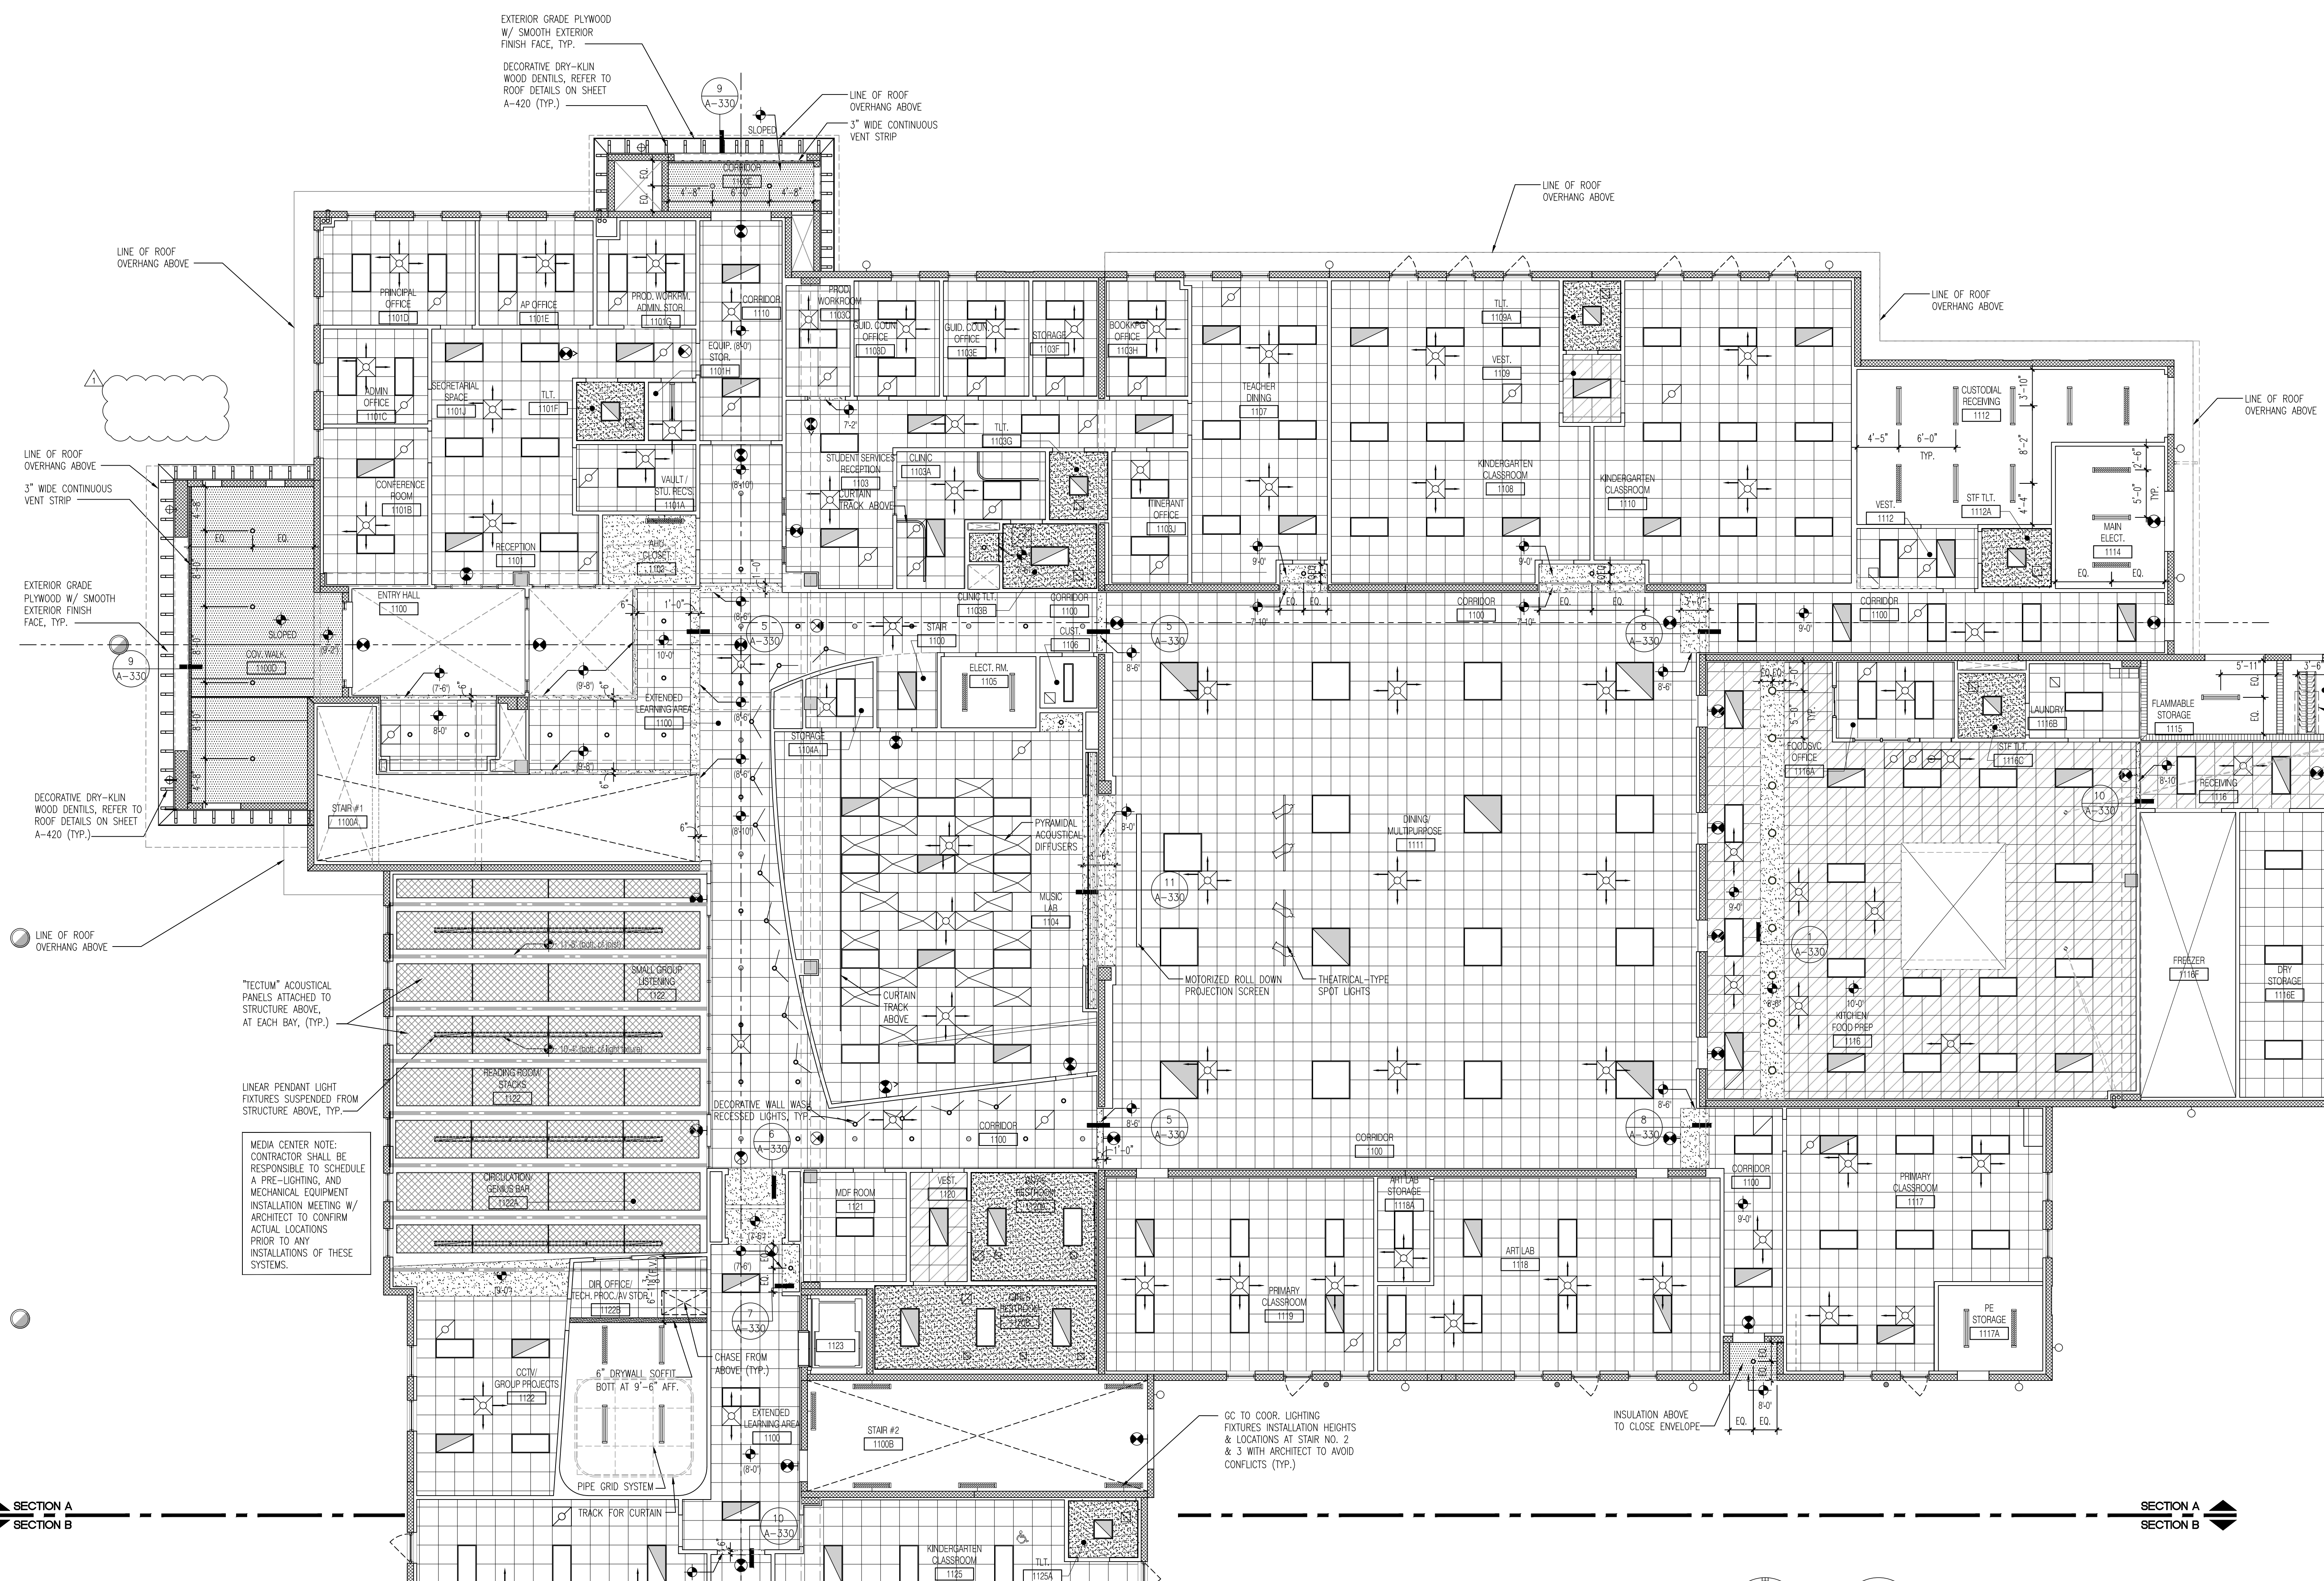


1
A-311
Scale: 1/8" = 1'-0"

NEW ELEMENTARY SCHOOL (K-5)
VENETIAN PARC WEST
SOUTHWEST 157th AVENUE and 174th STREET
MIAMI, FL. 33187
MDCPS PROJECT No. 01892600

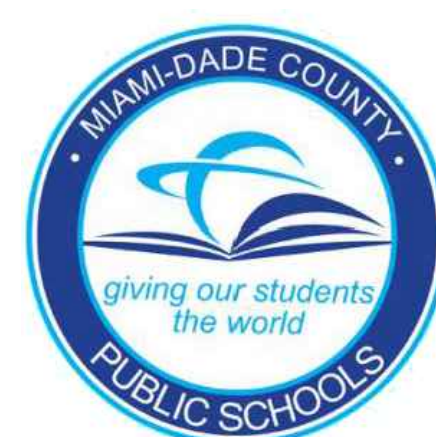

KEY PLAN

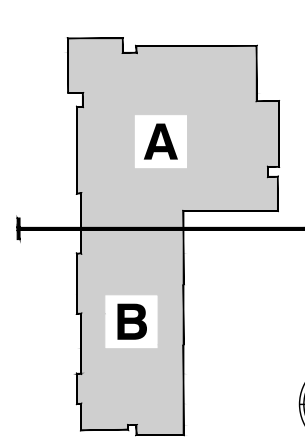

CONSULTANT INFO:

DATE: 12/16/19
PROJECT NO: 1906
SHEET: A-311

RODRIGUEZ ARCHITECTS INCORPORATED
2121 PONCE DE LEON BLVD. STE. 1010
CORAL GABLES, FL. 33134
TEL: (305) 448-3373
FAX: (305) 448-3374
A A C - 0 0 1 9 3 3

RAI

REVISIONS:

DATE	DESCRIPTION
02/14/2020	BUILDING DEPARTMENT COMMENTS

DRAWING TITLE:

FIRST FLOOR REFL. CEILING PLAN AREA A	
SCALE AS NOTED	
ISSUE DATE 12/16/19	PROJECT NO. 1906
SHEET: A-311	

CHECKED BY: LR	DRAWN BY: C.V.
-------------------	-------------------



REFL. CEILING PLAN LEGEND			
1X4 FLUORESCENT LIGHT FIXTURE	2X4 FLUORESCENT LIGHT FIXTURE	2X2 INDIRECT FLUORESCENT LIGHT FIXTURE	FLUORESCENT STRIP LIGHT FIXTURE
WALL MTD. FLUORESCENT STRIP LIGHT FIXTURE	PENDANT LIGHT FIXTURE	WALL MTD. LIGHT FIXTURE	RECESSED HIGH-HAT LIGHT FIXTURE
EXIT SIGN	EXIT SIGN (WALL MOUNT)	A/C SUPPLY GRILL (SEE MECHANICAL DRAWINGS FOR SIZE, OUTPUT, ETC.)	2'X4' PYRAMIDAL ACOUSTICAL DIFFUSER PANEL
INCANDESCENT OR H.I.D. LIGHT FIXTURE (SEE REFL. LT. FINISH SCH.)	EXHAUST FAN	RETURN OR OUTSIDE AIR DUCT	CEILING FAN
1X4 EMERGENCY FLUORESCENT LIGHT FIXTURE	2X4 EMERGENCY FLUORESCENT LIGHT FIXTURE	2X2 EMERGENCY INDIRECT FLUORESCENT LIGHT FIXTURE	EMERGENCY FLUORESCENT STRIP LIGHT FIXTURE
EMERGENCY WALL MTD. FLUORESCENT STRIP LIGHT FIXTURE	EMERGENCY WALL MTD. FLUORESCENT STRIP LIGHT FIXTURE	CEILING MOUNTED TRACK LIGHTS	WALL MOUNTED WALL WASHER
RECESSED EMERGENCY HIGH HAT LIGHT FIXTURE	EMER. WALL MOUNTED LIGHT FIXTURE	A/C AIR RETURN GRILL (SEE MECHANICAL DRAWINGS FOR SIZE, OUTPUT, ETC.)	SECURITY CAMERA LOCATION (SEE ELECTRICAL DRAWINGS FOR SIZE, CONDUIT, ETC.)
EMERGENCY LIGHT FIXTURE	CEILING PROJECTOR (NIC) (SEE ENLARGEMENT PLAN A-700'S FOR ACTUAL LOCATION, DIRECTION, ETC.)	CEILING SPEAKER	WOOD MOLDING AND DENTILS (AT FULL PERIMETER)
2' X 4' ACOUSTICAL LAY-IN CEILING	2' X 2' ACOUSTICAL LAY-IN CEILING	2' X 2' ACOUSTICAL WASHABLE SURFACE	EXPOSED STRUCTURE
GYPSUM WALL BOARD CEILING OR SOFFIT AREA	2 COATS CEMENT PLASTER ON MTL. LATH - SEE STRUCT. DWGS. FRAMING/SUPPORT	2 COATS CEMENT PLASTER ON ON CEMENT BOARD	EPOXY PAINT ON MOISTURE RESISTANT GYPSUM BOARD

- ### REFL. CEILING GENERAL NOTES
- DIMENSIONS NOTED IN EACH AREA DESIGNATE CEILING HEIGHT ABOVE FINISH FLOOR.
 - SEE PLUMB., ELEC. AND FIRE PROT. DRAWINGS FOR LOCATIONS OF SPRINKLER HEADS AND LIGHT FIXTURES IN EXPOSED CEILING AREAS. CONTRACTOR TO COORDINATE FINAL FIRE PROTECTION DRAWINGS WITH ARCHITECT FOR LAYOUT CONFIRMATION.
 - ALL SYSTEMS FIXTURES ARE TO BE LOCATED CENTER OF TILE (TYP.).
 - CONTRACTOR TO COORDINATE ALL DISCIPLINES TO ENSURE CLEARANCES FOR ALL DUCTWORK, EQUIPMENT, FIXTURES, PIPES, CONDUITS, AND CEILING SYSTEMS NECESSARY TO MAINTAIN CEILING ELEVATIONS NOTED.
 - ALL EXPOSED CEILING AREAS TO BE FULLY PAINTED. COORDINATE ALL COLOR SELECTIONS WITH ARCHITECT. SYSTEMS COLORS TO BE CUSTOM. (WHERE DUCTWORK IS EXPOSED IN OCCUPIED SPACES - DUCTWORK SHALL BE ROUND DOUBLE WALL METAL.)
 - EXPOSED SYSTEMS AREAS TO BE COORDINATED AND LOCATED IN A CLEAN AND ORGANIZED FASHION. ALL ELECTRICAL CONDUIT AND JUNCTION BOXES TO BE MOUNTED AT UNDERSIDE OF DECK (NO RUNS OR TERMINATIONS AT JOISTS).
 - ALL WALL PENETRATIONS TO EXPOSED CEILING AREAS TO BE CONSTRUCTED WITH APPROVED UL ASSEMBLY PROTECTION, PER WALL RATING REQUIREMENTS.
 - CONTRACTOR TO COORDINATE ALL DUCT LOCATIONS WITH ALL OTHER TRADES. ARCHITECT TO REVIEW AND HAVE FINAL APPROVAL FOR ALL EXPOSED CEILING AREAS.
 - ALL SECURITY CAMERA LOCATIONS TO HAVE JUNCTION BOX WITH COVER AND CONDUIT TAIL (WITH PULL STRING) TO ABOVE CEILING AREA (ACCESSIBLE) AS DESIGNATED BY OWNER - SEE ELECTRICAL DRAWINGS. ALL EXTERIOR LOCATIONS TO HAVE DAMP-PROOF BOX.
 - ALL CLASSROOMS, LABS AND TEACHING SPACES TO BE PROVIDED WITH INFRASTRUCTURE PROVISION FOR FUTURE FULL AUDIO ENHANCEMENT SYSTEM.
 - ALL CEILING RECESSED OR MOUNTED PROJECTION SCREENS ARE TO BE MOTORIZED. CONTRACTOR TO PROVIDE REQUIRED ELECTRICAL (AND DATA IF REQUIRED) SYSTEMS CONNECTIONS FOR COMPLETE SYSTEM INSTALLATION.
 - ALL DECORATIVE LIGHT FIXTURES ARE TO BE COORDINATED WITH ARCHITECT FOR FINAL SELECTION OF FIXTURE, FINISH AND LOCATION.
 - ALL OCCUPIED SPACES ARE TO HAVE OCCUPANCY SENSORS FOR ADDITIONAL LIGHT CONTROLS.
 - REFER TO SECTIONS, WALL SECTIONS AND ROOF DETAILS FOR ALL OVERHANG AND DENTIL DETAILS.
 - CONTRACTOR TO COORDINATE ALL LOCATIONS FOR INTERIOR AND EXTERIOR STUCCO AND PLASTER FINISH REVEALS WITH ARCHITECT. CONTRACTOR TO PROVIDE SHOP DRAWING LAYOUT FOR ALL REQUIRED REVEALS AND CONTROL JOINTS.
 - ALL PAINT FINISH HARD SOFFITS ARE TO BE PAINTED WHITE UNLESS OTHERWISE NOTED.
 - ALL SYSTEMS ARE TO BE LOCATED AND INSTALLED IN AN ORGANIZED NATURE FOR ALL CEILING AREAS. ANY CONFLICTS ARE TO BE NOTED TO ARCHITECT PRIOR TO INSTALLATION.
 - FINAL ELEVATIONS OF LIGHT FIXTURES (PENDENT AND INDIRECT) ARE TO BE COORDINATED WITH ARCHITECT AT TIME OF SHOP DRAWING AND PRODUCT REVIEW SUBMISSION.
 - ALL FIRE PROTECTION SPRINKLERS ARE TO BE SEMI-RECESSED TYPE WITH FINISH TO BE COORDINATED WITH ARCHITECT.

NEW ELEMENTARY SCHOOL (K-5)

VENETIAN PARC WEST

SOUTHWEST 157th AVENUE and 174th STREET
MIAMI, FL. 33187
MDCPS PROJECT No. 01892600

KEY PLAN

CONSULTANT INFO:

RODRIGUEZ ARCHITECTS INCORPORATED

2121 PONCE DE LEON BLVD. STE. 1010
CORAL GABLES, FL. 33134
TEL: (305) 448-3373
FAX: (305) 448-3374
A A C — 0 0 1 9 3 3

CHECKED BY: LR.

DRAWN BY: C.V.

CONSULTANT INFO:

MIAMI-DADE COUNTY PUBLIC SCHOOLS

giving our students the world

DRAWING TITLE:


FIRST FLOOR REFL. CEILING PLAN AREA B

SCALE AS NOTED

ISSUE DATE: 12/16/14

PROJECT NO: 1906

SHEET: A-312

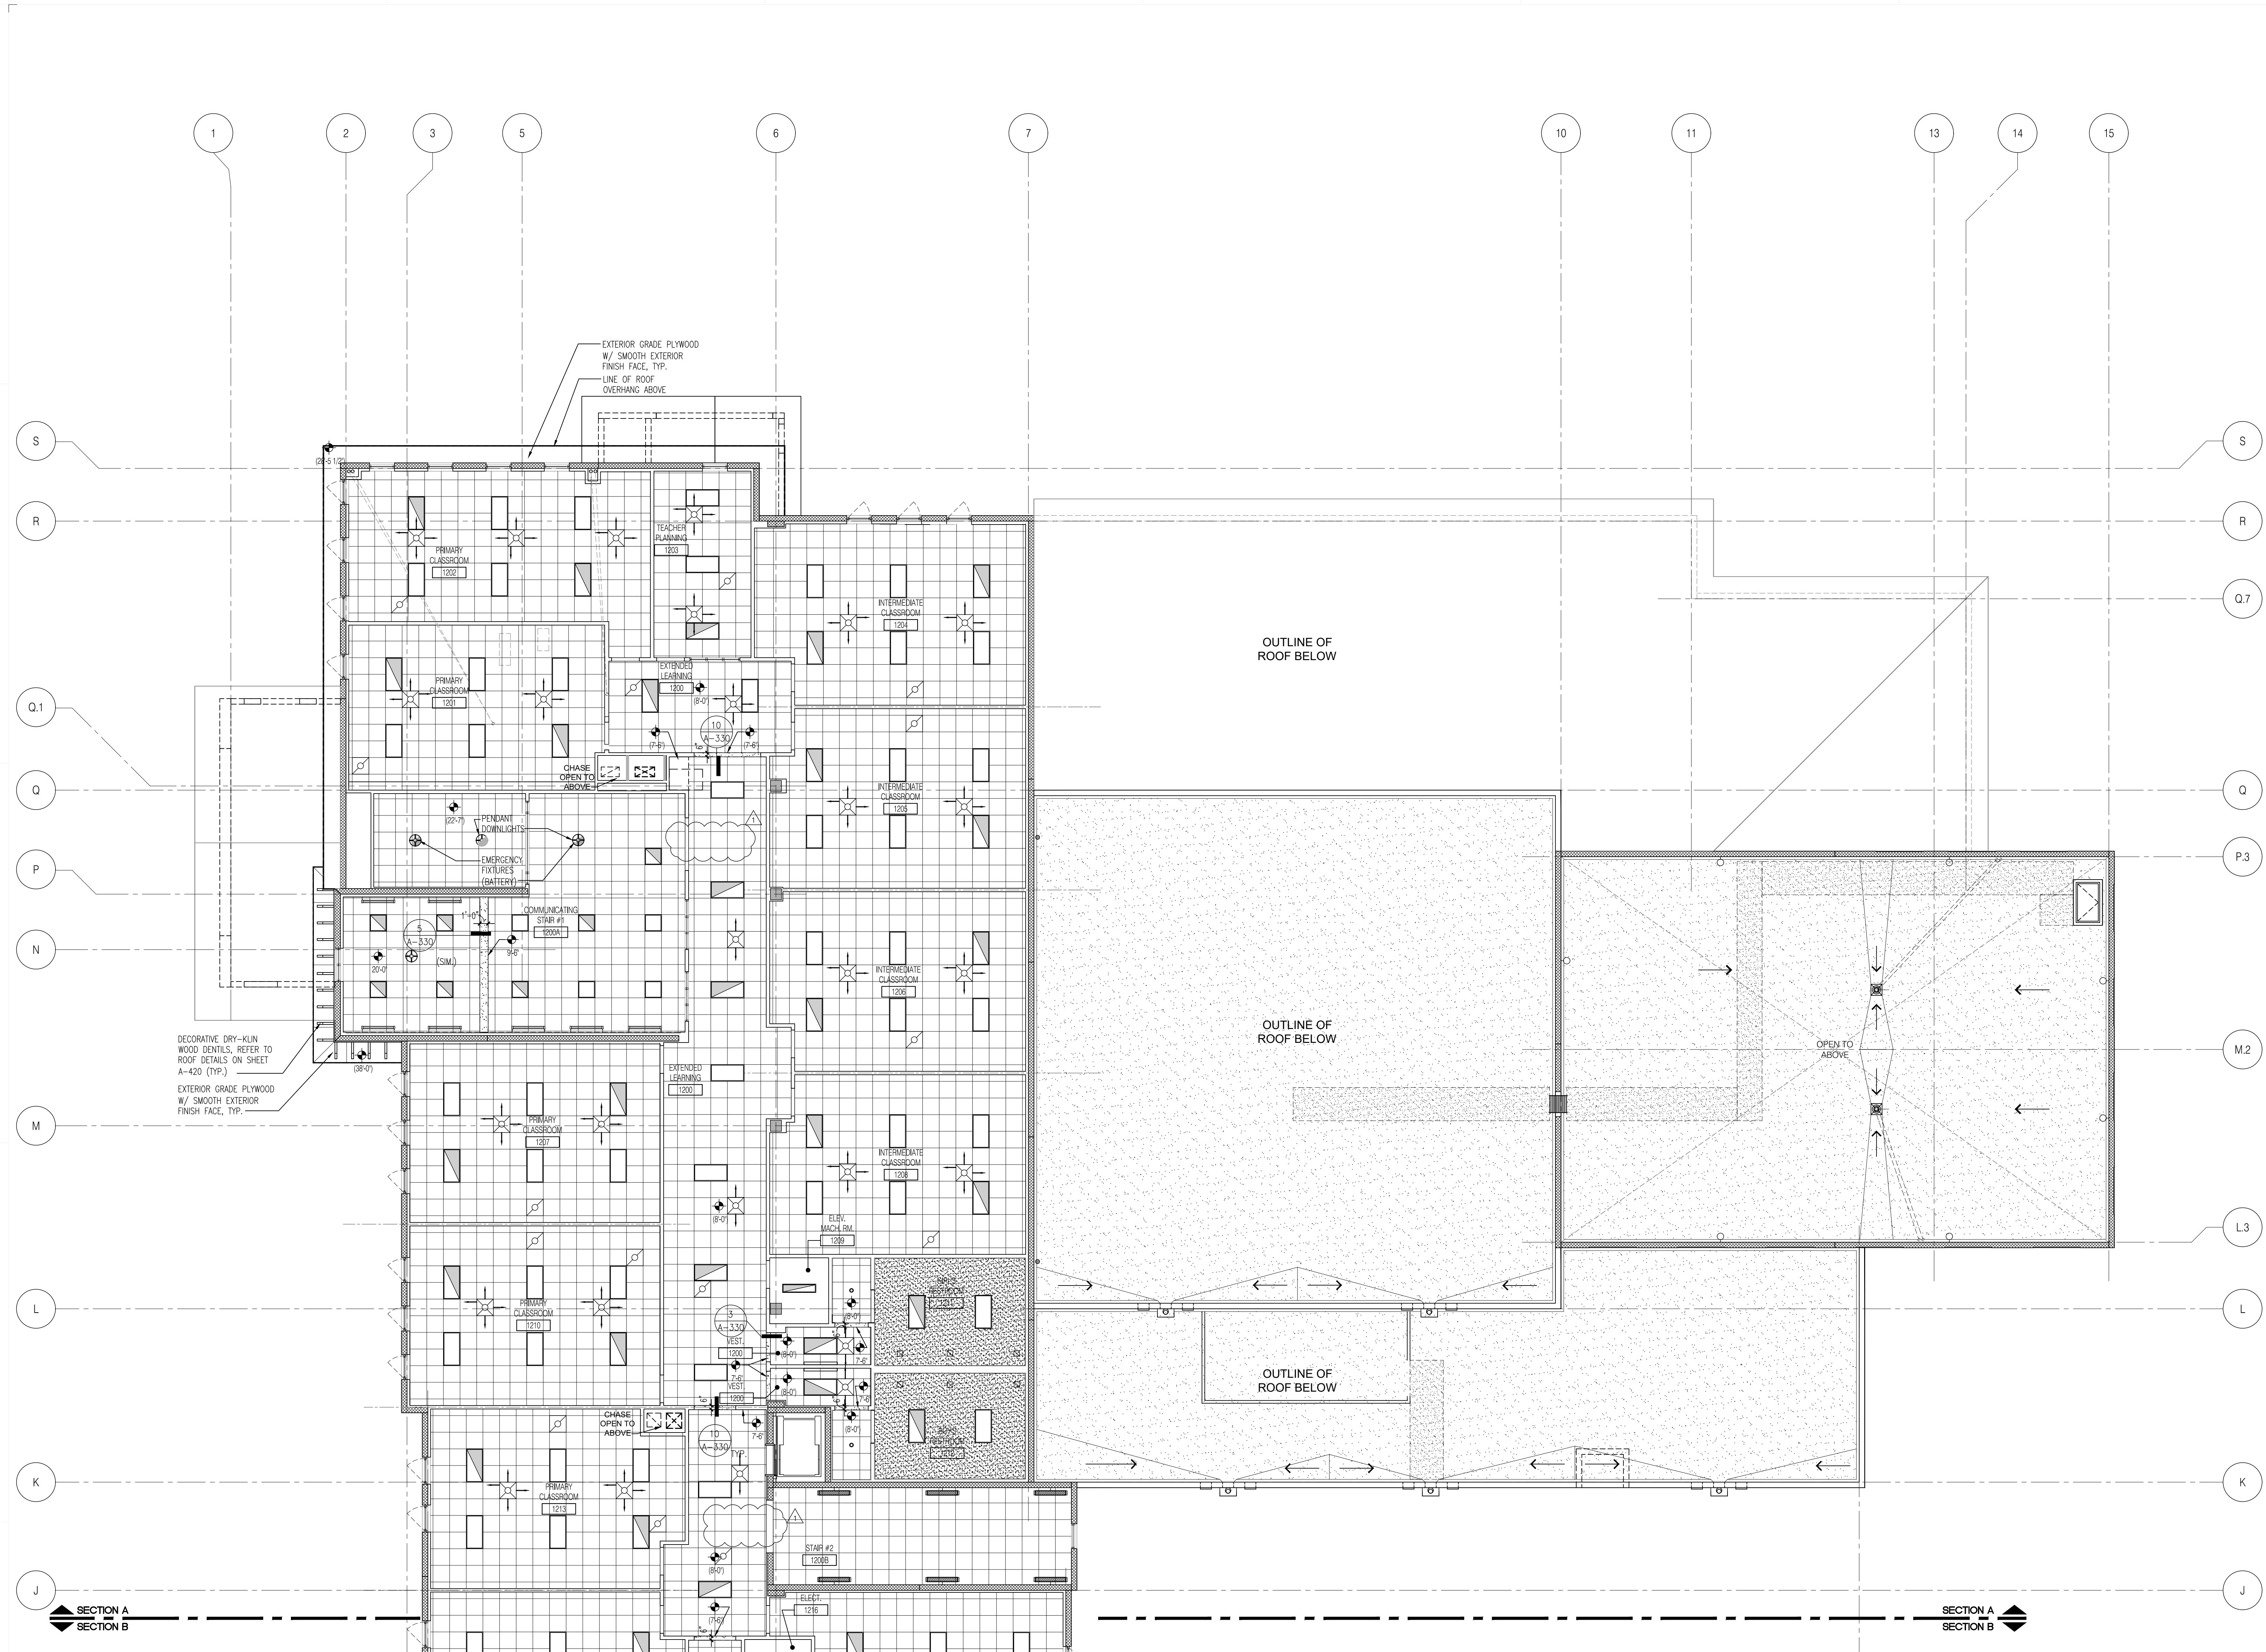

REFL. CEILING PLAN LEGEND			
	1X4 FLUORESCENT LIGHT FIXTURE		1X4 EMERGENCY FLUORESCENT LIGHT FIXTURE
	2X4 FLUORESCENT LIGHT FIXTURE		2X4 EMERGENCY FLUORESCENT LIGHT FIXTURE
	2X2 INDIRECT FLUORESCENT LIGHT FIXTURE		2X2 EMERGENCY INDIRECT FLUORESCENT LIGHT FIXTURE
	FLUORESCENT STRIP LIGHT FIXTURE		EMERGENCY FLUORESCENT STRIP LIGHT FIXTURE
	WALL MTD. FLUORESCENT STRIP LIGHT FIXTURE		EMERGENCY WALL MTD. FLUORESCENT STRIP LIGHT FIXTURE
	PENDANT LIGHT FIXTURE		CEILING MOUNTED TRACK LIGHTS
	WALL MTD. LIGHT FIXTURE		WALL MOUNTED WALL WASHER
	RECESSED HIGH-HAT LIGHT FIXTURE		RECESSED EMERGENCY HIGH HAT LIGHT FIXTURE
	EXIT SIGN		EMER. WALL MOUNTED LIGHT FIXTURE
	EXIT SIGN (WALL MOUNT)		A/C AIR RETURN GRILL (SEE MECHANICAL DRAWINGS FOR SIZE, OUTPUT, ETC.)
	A/C SUPPLY GRILL (SEE MECHANICAL DRAWINGS FOR SIZE, OUTPUT, ETC.)		SECURITY CAMERA LOCATION (SEE ELECTRICAL DRAWINGS FOR SIZE, CONDUIT, ETC.)
	2'X4' PYRAMIDAL ACOUSTICAL DIFFUSER PANEL		EMERGENCY LIGHT FIXTURE
	INCANDESCENT OR H.I.D. LIGHT FIXTURE (SEE REFL. LT. FINISH SCH.)		CEILING PROJECTOR (NIC) (SEE ENLARGEMENT PLAN A-700'S FOR ACTUAL LOCATION, DIRECTION, ETC.)
	EXHAUST FAN		CEILING SPEAKER
	RETURN OR OUTSIDE AIR DUCT		WOOD MOLDING AND DENTILS (AT FULL PERIMETER)
	CEILING FAN		2' X 4' ACOUSTICAL LAY-IN CEILING
	2' X 2' ACOUSTICAL LAY-IN CEILING		2 COATS CEMENT PLASTER ON MTL. LATH - SEE STRUCT. DWGS. FRAMING/SUPPORT
	2' X 2' ACOUSTICAL WASHABLE SURFACE		2 COATS CEMENT PLASTER ON MTL. LATH - SEE STRUCT. DWGS. FRAMING/SUPPORT
	EXPOSED STRUCTURE		EPOXY PAINT ON MOISTURE RESISTANT GYPSUM BOARD


- REFL. CEILING GENERAL NOTES**
- DIMENSIONS NOTED IN EACH AREA DESIGNATE CEILING HEIGHT ABOVE FINISH FLOOR.
 - SEE PLUMB., ELEC. AND FIRE PROT. DRAWINGS FOR LOCATIONS OF SPRINKLER HEADS AND LIGHT FIXTURES IN EXPOSED CEILING AREAS. CONTRACTOR TO COORDINATE FINAL FIRE PROTECTION DRAWINGS WITH ARCHITECT FOR LAYOUT CONFIRMATION.
 - ALL SYSTEMS FIXTURES ARE TO BE LOCATED CENTER OF TILE (TYP.).
 - CONTRACTOR TO COORDINATE ALL DISCIPLINES TO ENSURE CLEARANCES FOR ALL DUCTWORK, EQUIPMENT, FIXTURES, PIPES, CONDUITS, AND CEILING SYSTEMS NECESSARY TO MAINTAIN CEILING ELEVATIONS NOTED.
 - ALL EXPOSED CEILING AREAS TO BE FULLY PAINTED. COORDINATE ALL COLOR SELECTIONS WITH ARCHITECT. SYSTEMS COLORS TO BE CUSTOM. (WHERE DUCTWORK IS EXPOSED IN OCCUPIED SPACES - DUCTWORK SHALL BE ROUND DOUBLE WALL METAL.)
 - EXPOSED SYSTEMS AREAS TO BE COORDINATED AND LOCATED IN A CLEAN AND ORGANIZED FASHION. ALL ELECTRICAL CONDUIT AND JUNCTION BOXES TO BE MOUNTED AT UNDERSIDE OF DECK (NO RUNS OR TERMINATIONS AT JOISTS).
 - ALL WALL PENETRATIONS TO EXPOSED CEILING AREAS TO BE CONSTRUCTED WITH APPROVED UL ASSEMBLY PROTECTION, PER WALL RATING REQUIREMENTS.
 - CONTRACTOR TO COORDINATE ALL DUCT LOCATIONS WITH ALL OTHER TRADES. ARCHITECT TO REVIEW AND HAVE FINAL APPROVAL FOR ALL EXPOSED CEILING AREAS.
 - ALL SECURITY CAMERA LOCATIONS TO HAVE JUNCTION BOX WITH COVER AND CONDUIT TAIL (WITH PULL STRING) TO ABOVE CEILING AREA (ACCESSIBLE) AS DESIGNATED BY OWNER - SEE ELECTRICAL DRAWINGS. ALL EXTERIOR LOCATIONS TO HAVE DAMP-PROOF BOX.
 - ALL CLASSROOMS, LABS AND TEACHING SPACES TO BE PROVIDED WITH INFRASTRUCTURE PROVISION FOR FUTURE FULL AUDIO ENHANCEMENT SYSTEM.
 - ALL CEILING RECESSED OR MOUNTED PROJECTION SCREENS ARE TO BE MOTORIZED. CONTRACTOR TO PROVIDE REQUIRED ELECTRICAL (AND DATA IF REQUIRED) SYSTEMS CONNECTIONS FOR COMPLETE SYSTEM INSTALLATION.
 - ALL DECORATIVE LIGHT FIXTURES ARE TO BE COORDINATED WITH ARCHITECT FOR FINAL SELECTION OF FIXTURE, FINISH AND LOCATION.
 - ALL OCCUPIED SPACES ARE TO HAVE OCCUPANCY SENSORS FOR ADDITIONAL LIGHT CONTROLS.
 - REFER TO SECTIONS, WALL SECTIONS AND ROOF DETAILS FOR ALL OVERHANG AND DENTIL DETAILS.
 - CONTRACTOR TO COORDINATE ALL LOCATIONS FOR INTERIOR AND EXTERIOR STUCCO AND PLASTER FINISH REVEALS WITH ARCHITECT. CONTRACTOR TO PROVIDE SHOP DRAWING LAYOUT FOR ALL REQUIRED REVEALS AND CONTROL JOINTS.
 - ALL PAINT FINISH HARD SOFFITS ARE TO BE PAINTED WHITE UNLESS OTHERWISE NOTED.
 - ALL SYSTEMS ARE TO BE LOCATED AND INSTALLED IN AN ORGANIZED NATURE FOR ALL CEILING AREAS. ANY CONFLICTS ARE TO BE NOTED TO ARCHITECT PRIOR TO INSTALLATION.
 - FINAL ELEVATIONS OF LIGHT FIXTURES (PENDENT AND INDIRECT) ARE TO BE COORDINATED WITH ARCHITECT AT TIME OF SHOP DRAWING AND PRODUCT REVIEW SUBMISSION.
 - ALL FIRE PROTECTION SPRINKLERS ARE TO BE SEMI-RECESSED TYPE WITH FINISH TO BE COORDINATED WITH ARCHITECT.

1
A-321
Scale: 1/8" = 1'-0"

SECOND FLOOR REFLECTED CEILING PLAN - AREA A


CHECKED BY: LR	DRAWN BY: C.V.
-------------------	-------------------

CONSULTANT INFO:

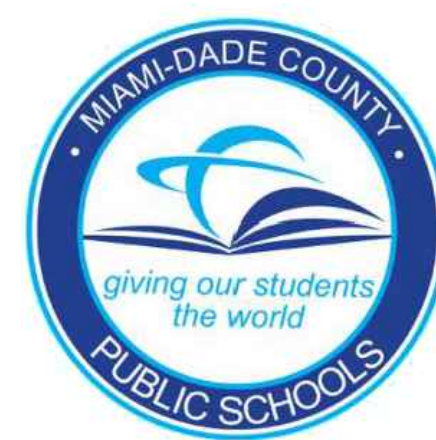

NEW ELEMENTARY SCHOOL (K-5)
VENETIAN PARC WEST
SOUTHWEST 157th AVENUE and 174th STREET
MIAMI, FL. 33187
MDCPS PROJECT No. 01892600

KEY PLAN

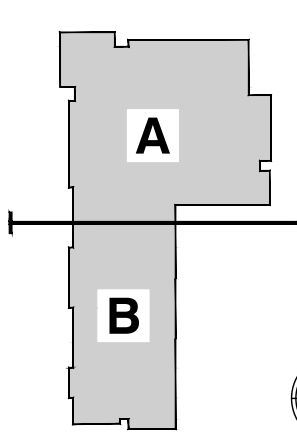

CONSULTANT INFO:

DATE: 02/14/2020
PROJECT NO: 01892600
SHEET: 1906

RODRIGUEZ ARCHITECTS INCORPORATED
2121 PONCE DE LEON BLVD. STE. 1010
CORAL GABLES, FL. 33134
TEL: (305) 448-3373
FAX: (305) 448-3374
A A C - 0 0 1 9 3 3

RAI


REVISIONS:

02/14/2020 BUILDING DEPARTMENT COMMENTS


DRAWING TITLE:

SECOND FLOOR REFLECTED CEILING PLAN AREA A


SCALE: AS NOTED
ISSUE DATE: 12/16/19
PROJECT NO: 1906
SHEET: A-321

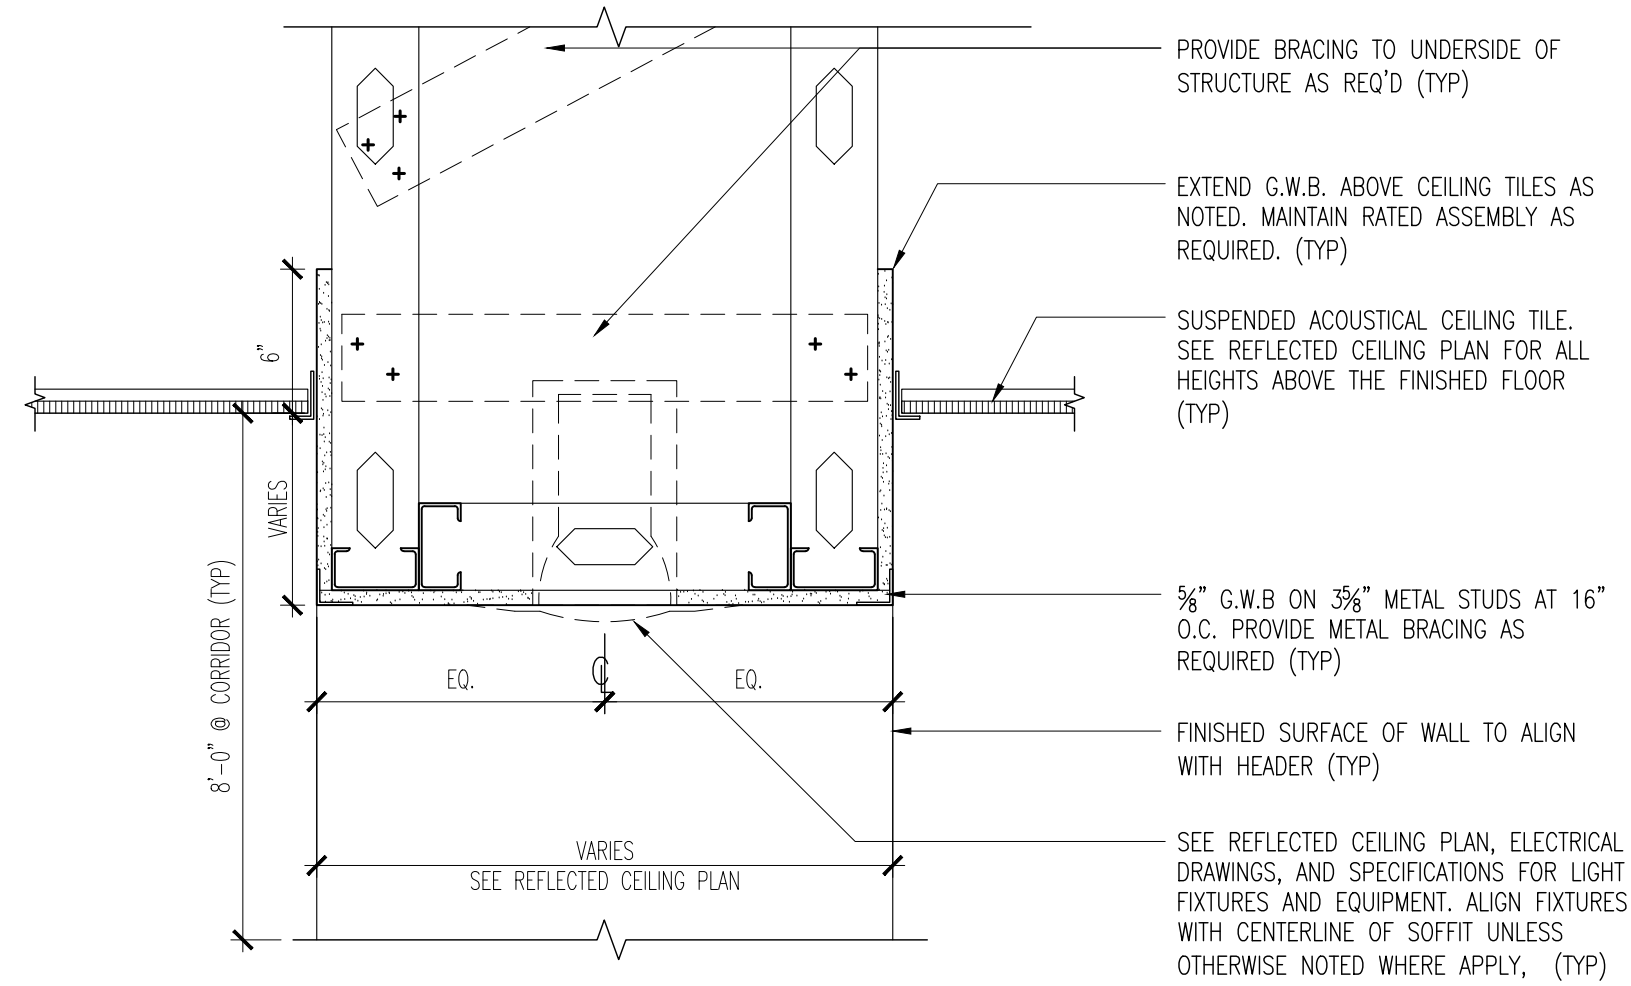


1 SOFFIT DETAIL
A-330 Scale: 1-1/2" = 1'-0"

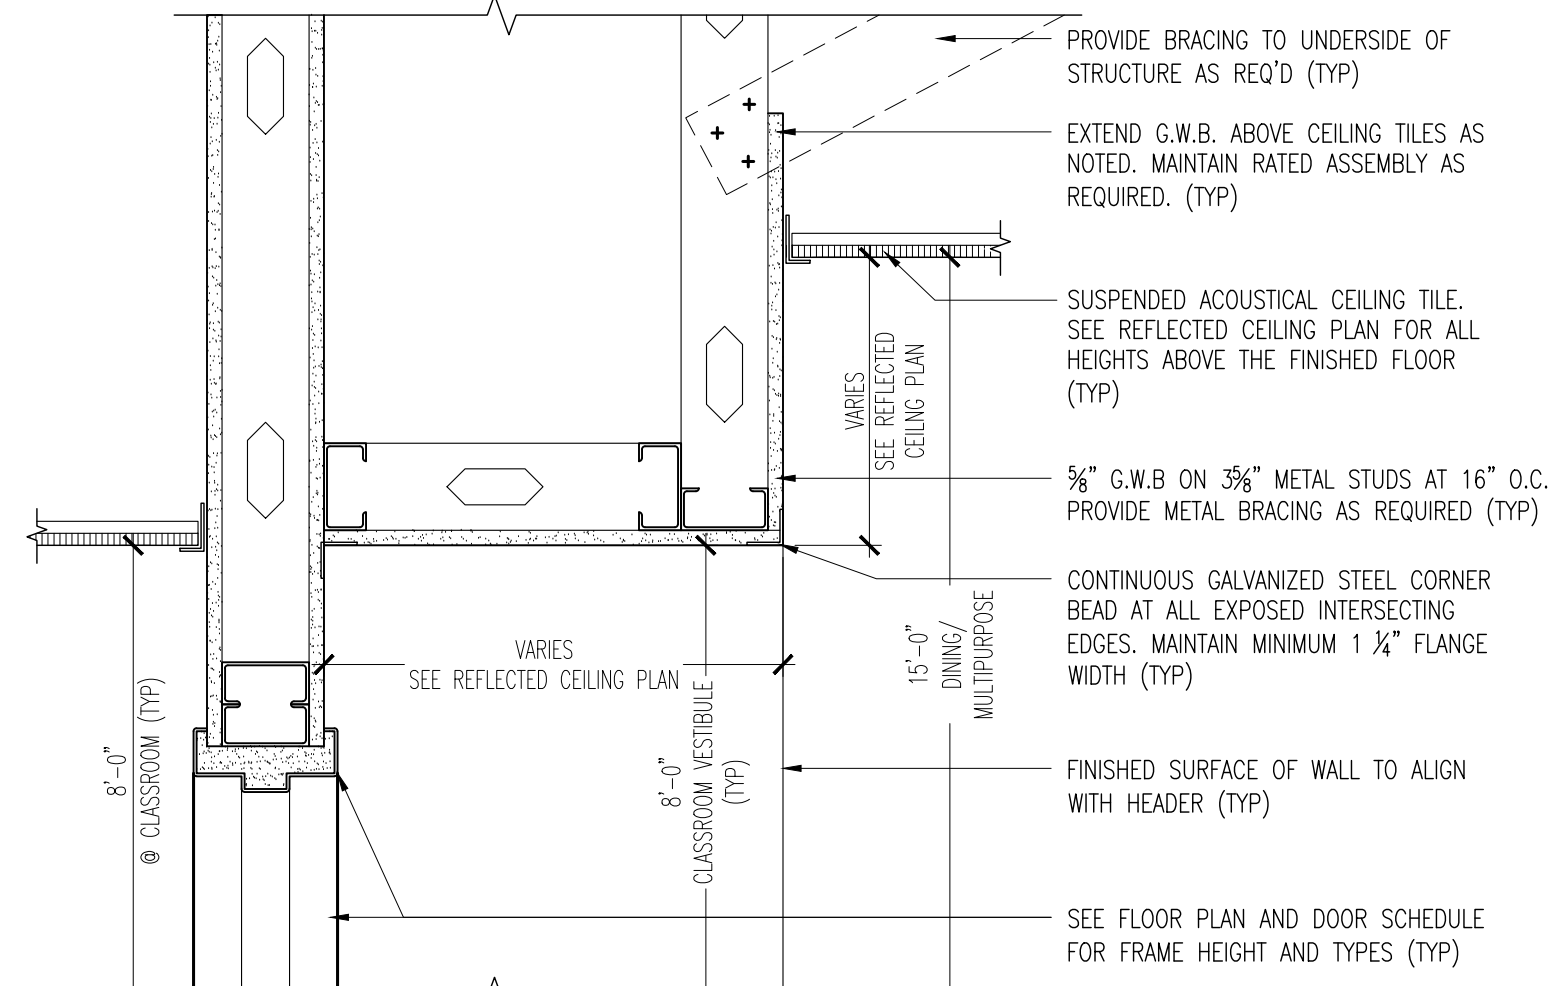


2 SOFFIT DETAIL
A-330 Scale: 1-1/2" = 1'-0"

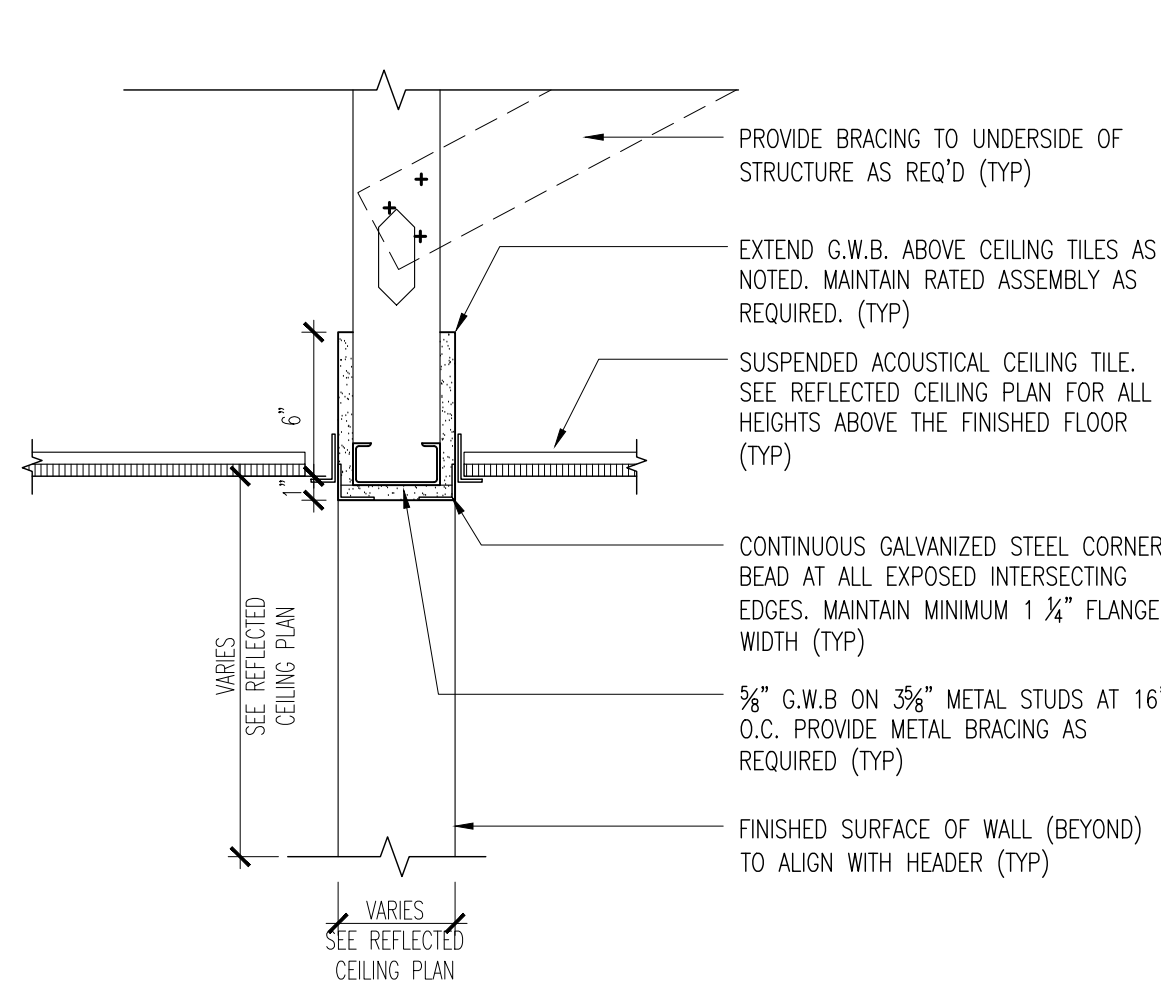


3 SOFFIT DETAIL
A-330 Scale: 1-1/2" = 1'-0"

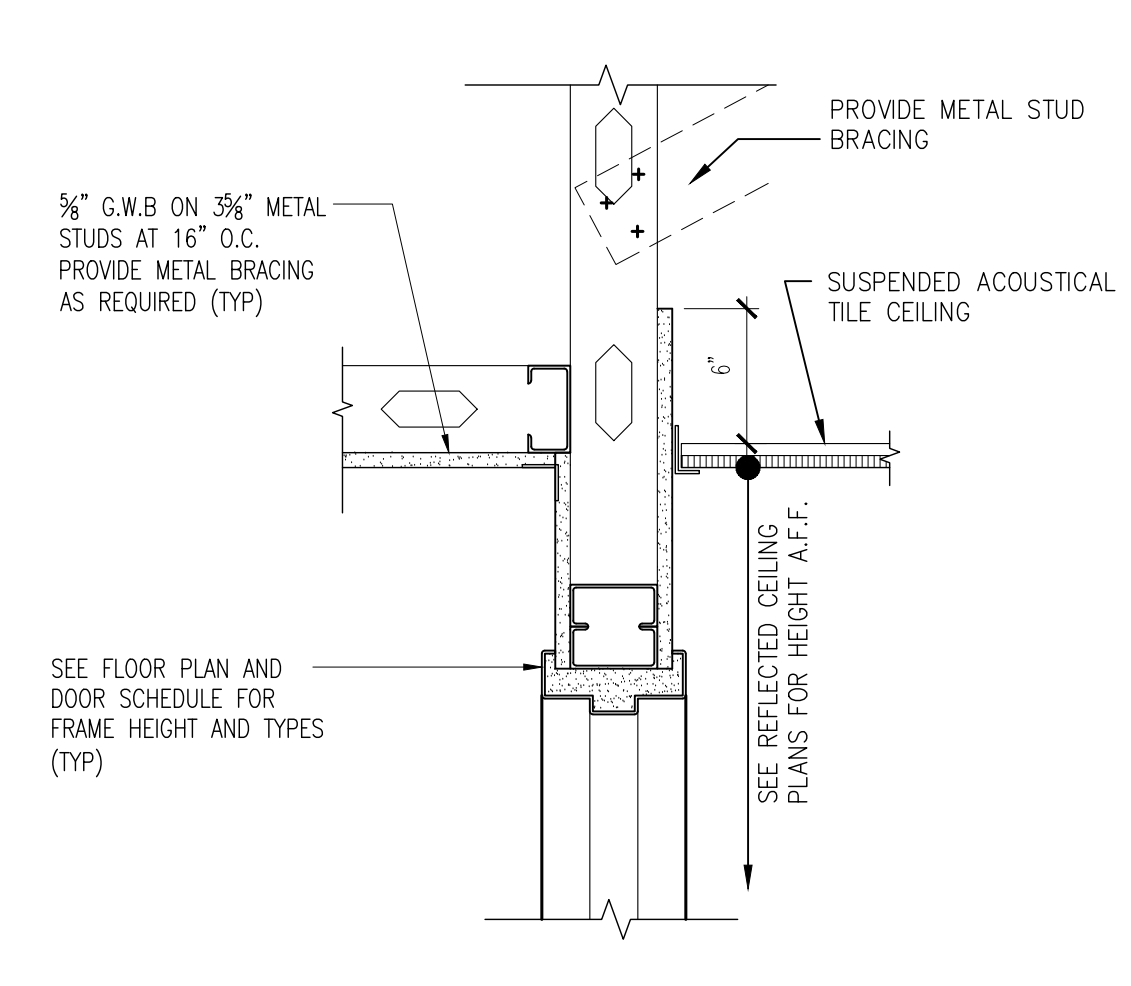


4 SOFFIT DETAIL
A-330 Scale: 1-1/2" = 1'-0"

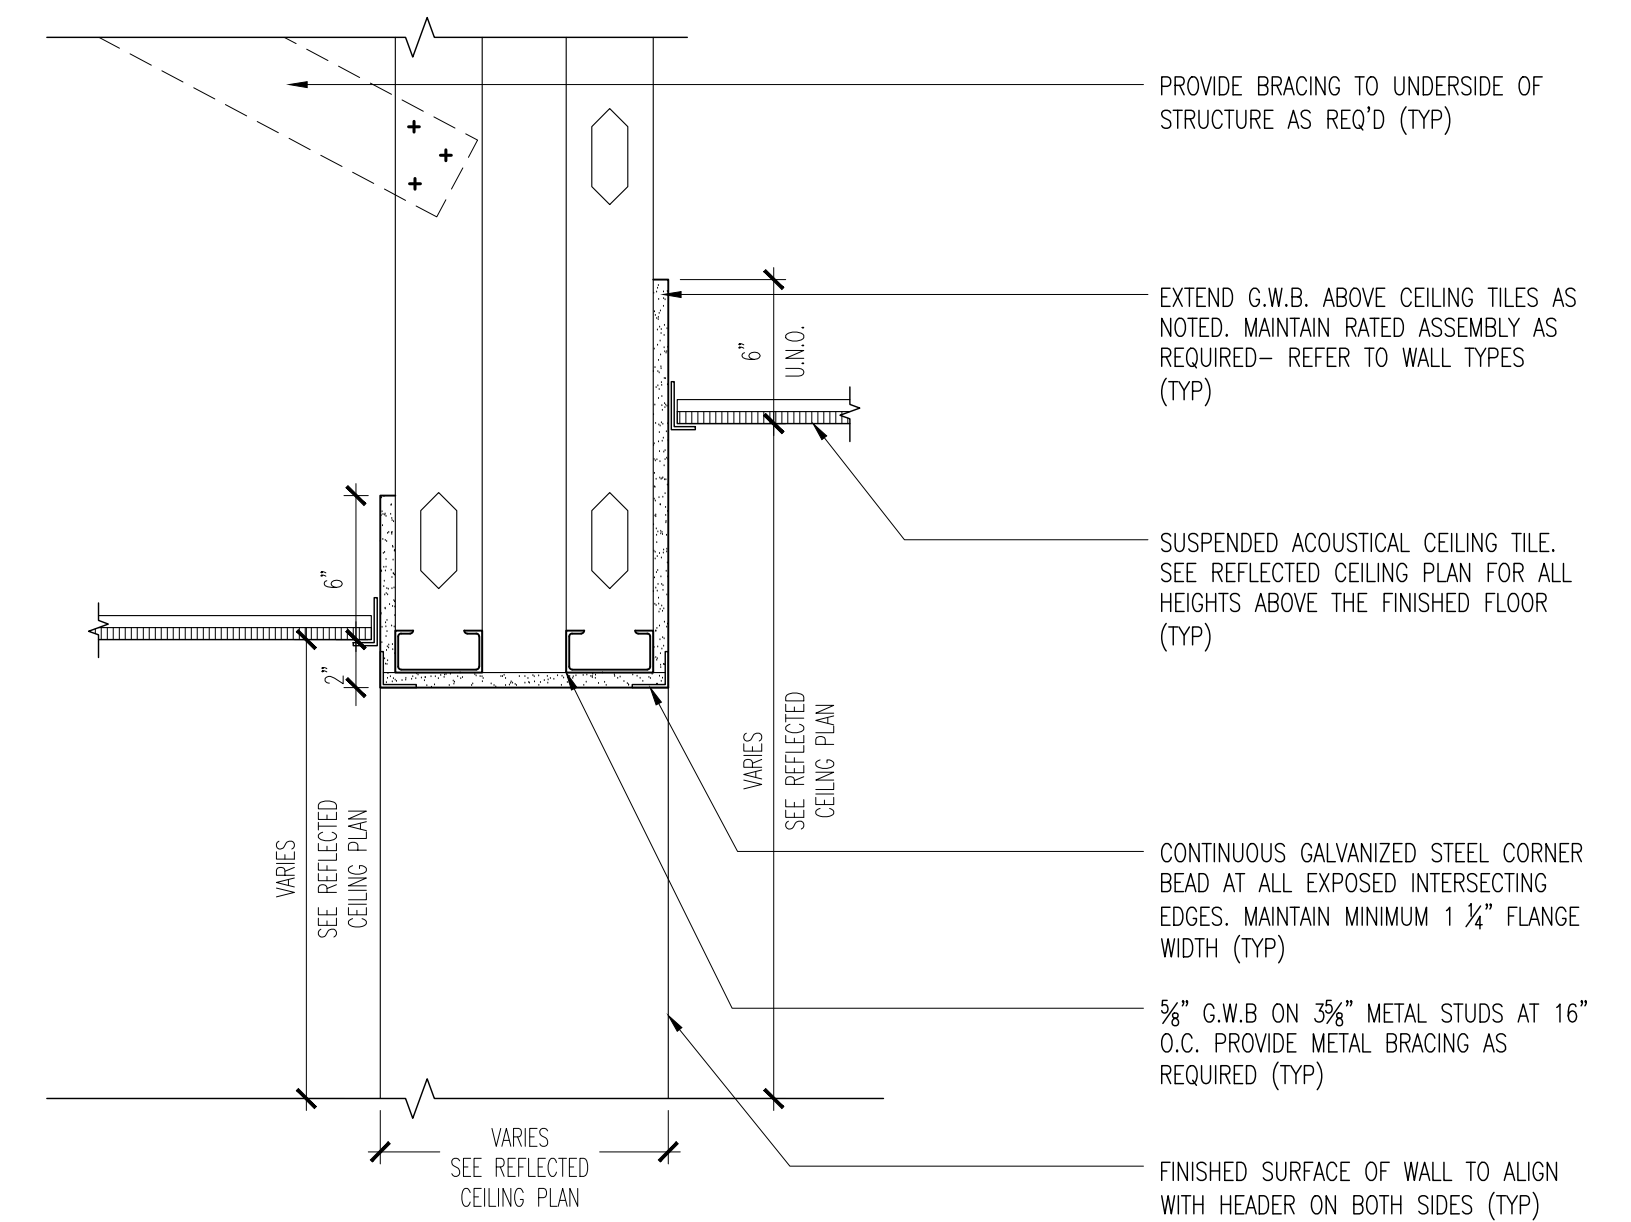


5 SOFFIT DETAIL - Dining-Hallway
A-330 Scale: 1-1/2" = 1'-0"

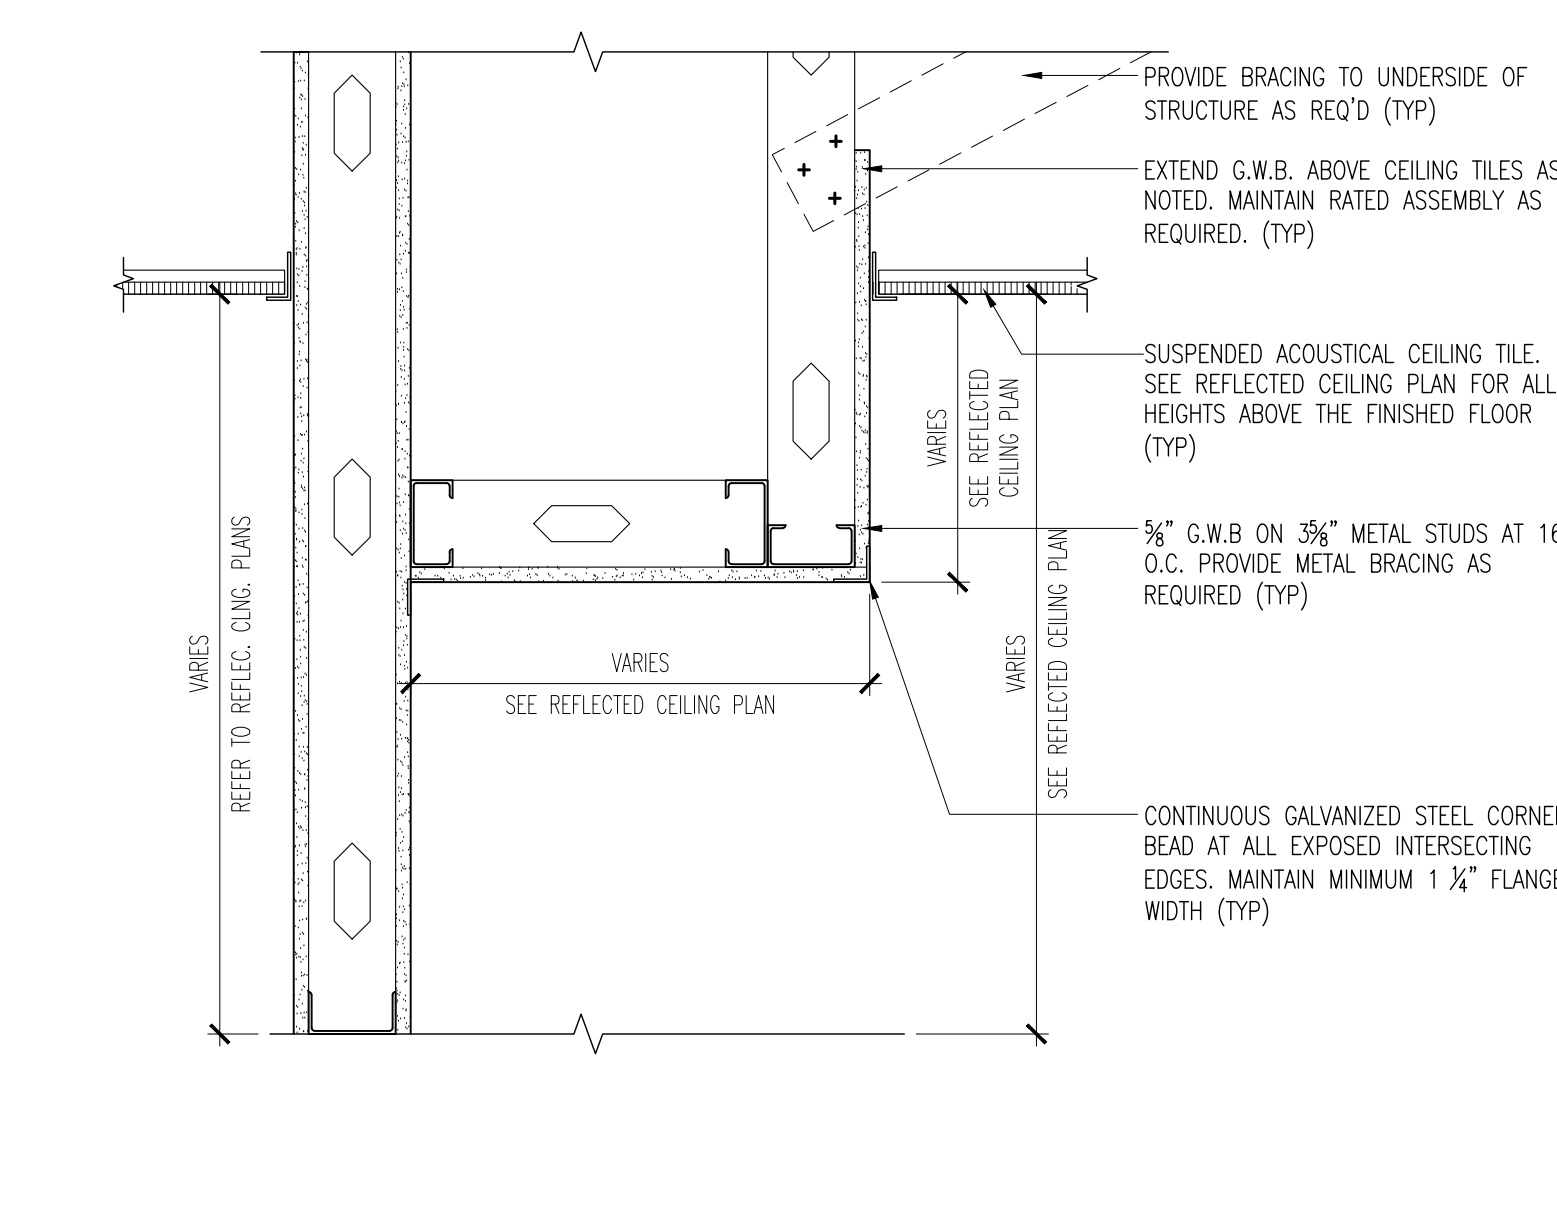


6 SOFFIT DETAIL - Salonetta
A-330 Scale: 1-1/2" = 1'-0"

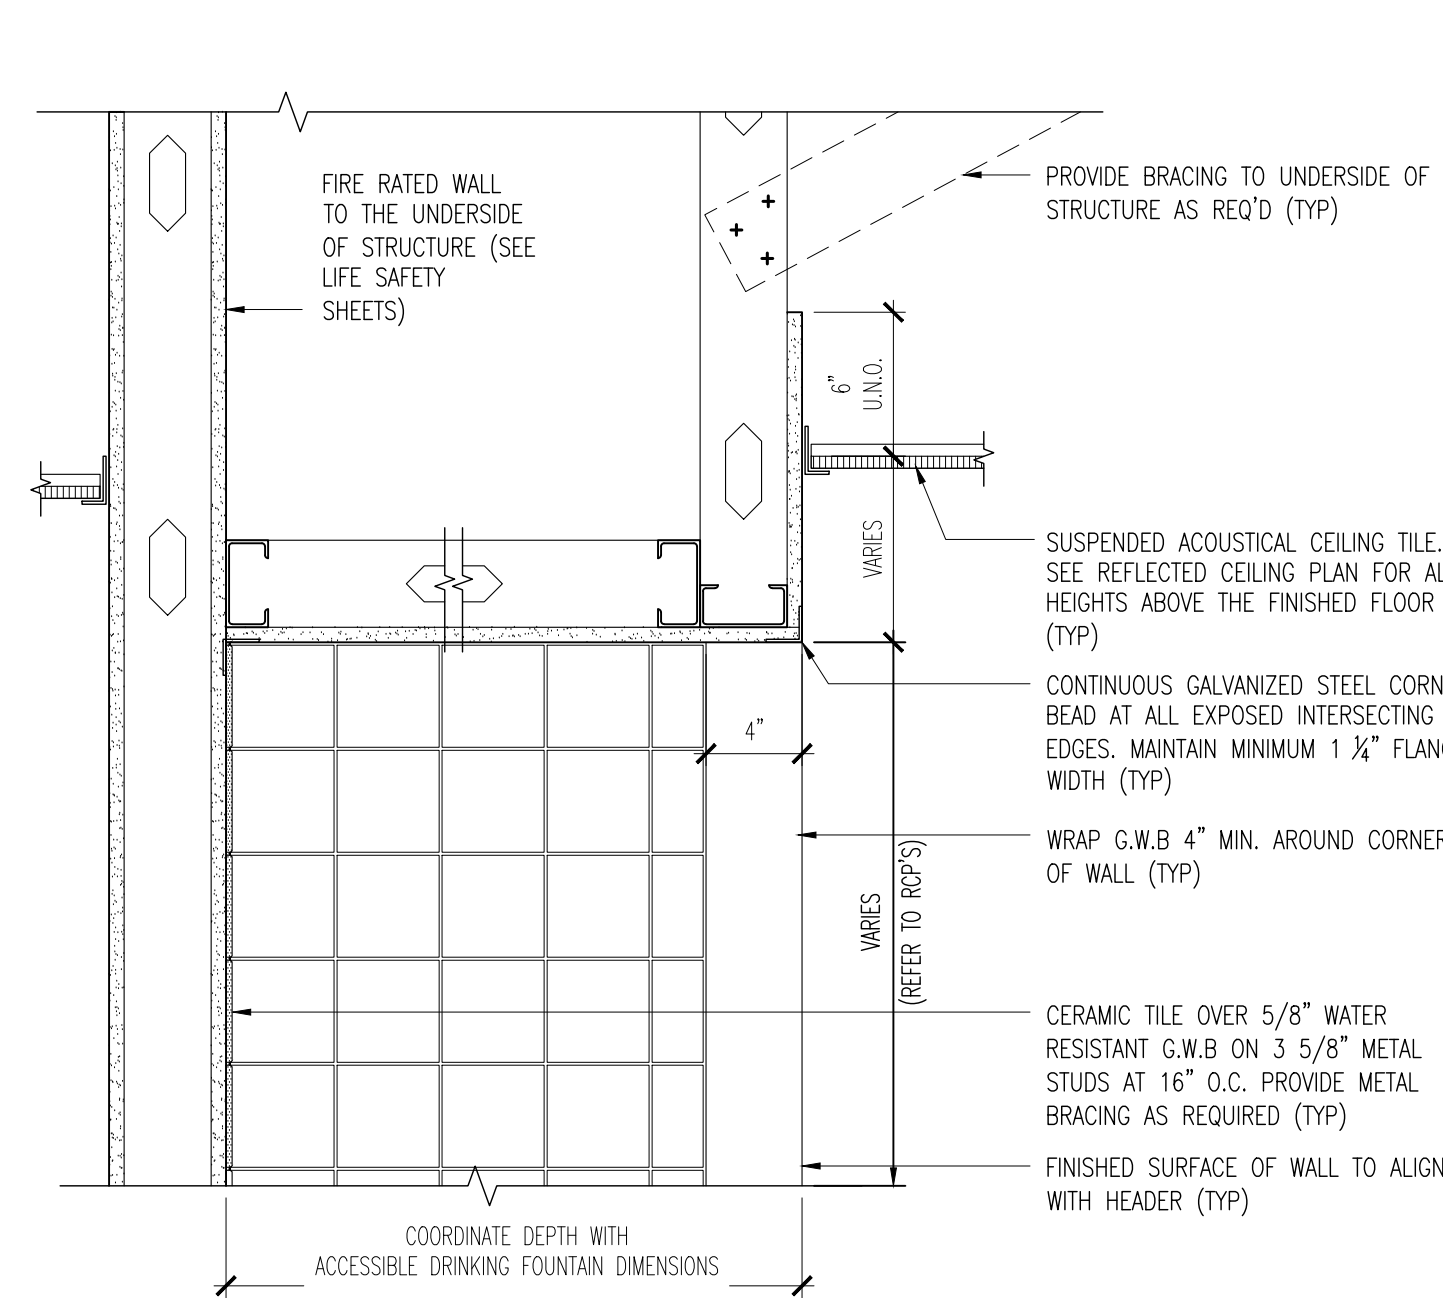


7 SOFFIT DETAIL - Drinking Fountain
A-330 Scale: 1-1/2" = 1'-0"

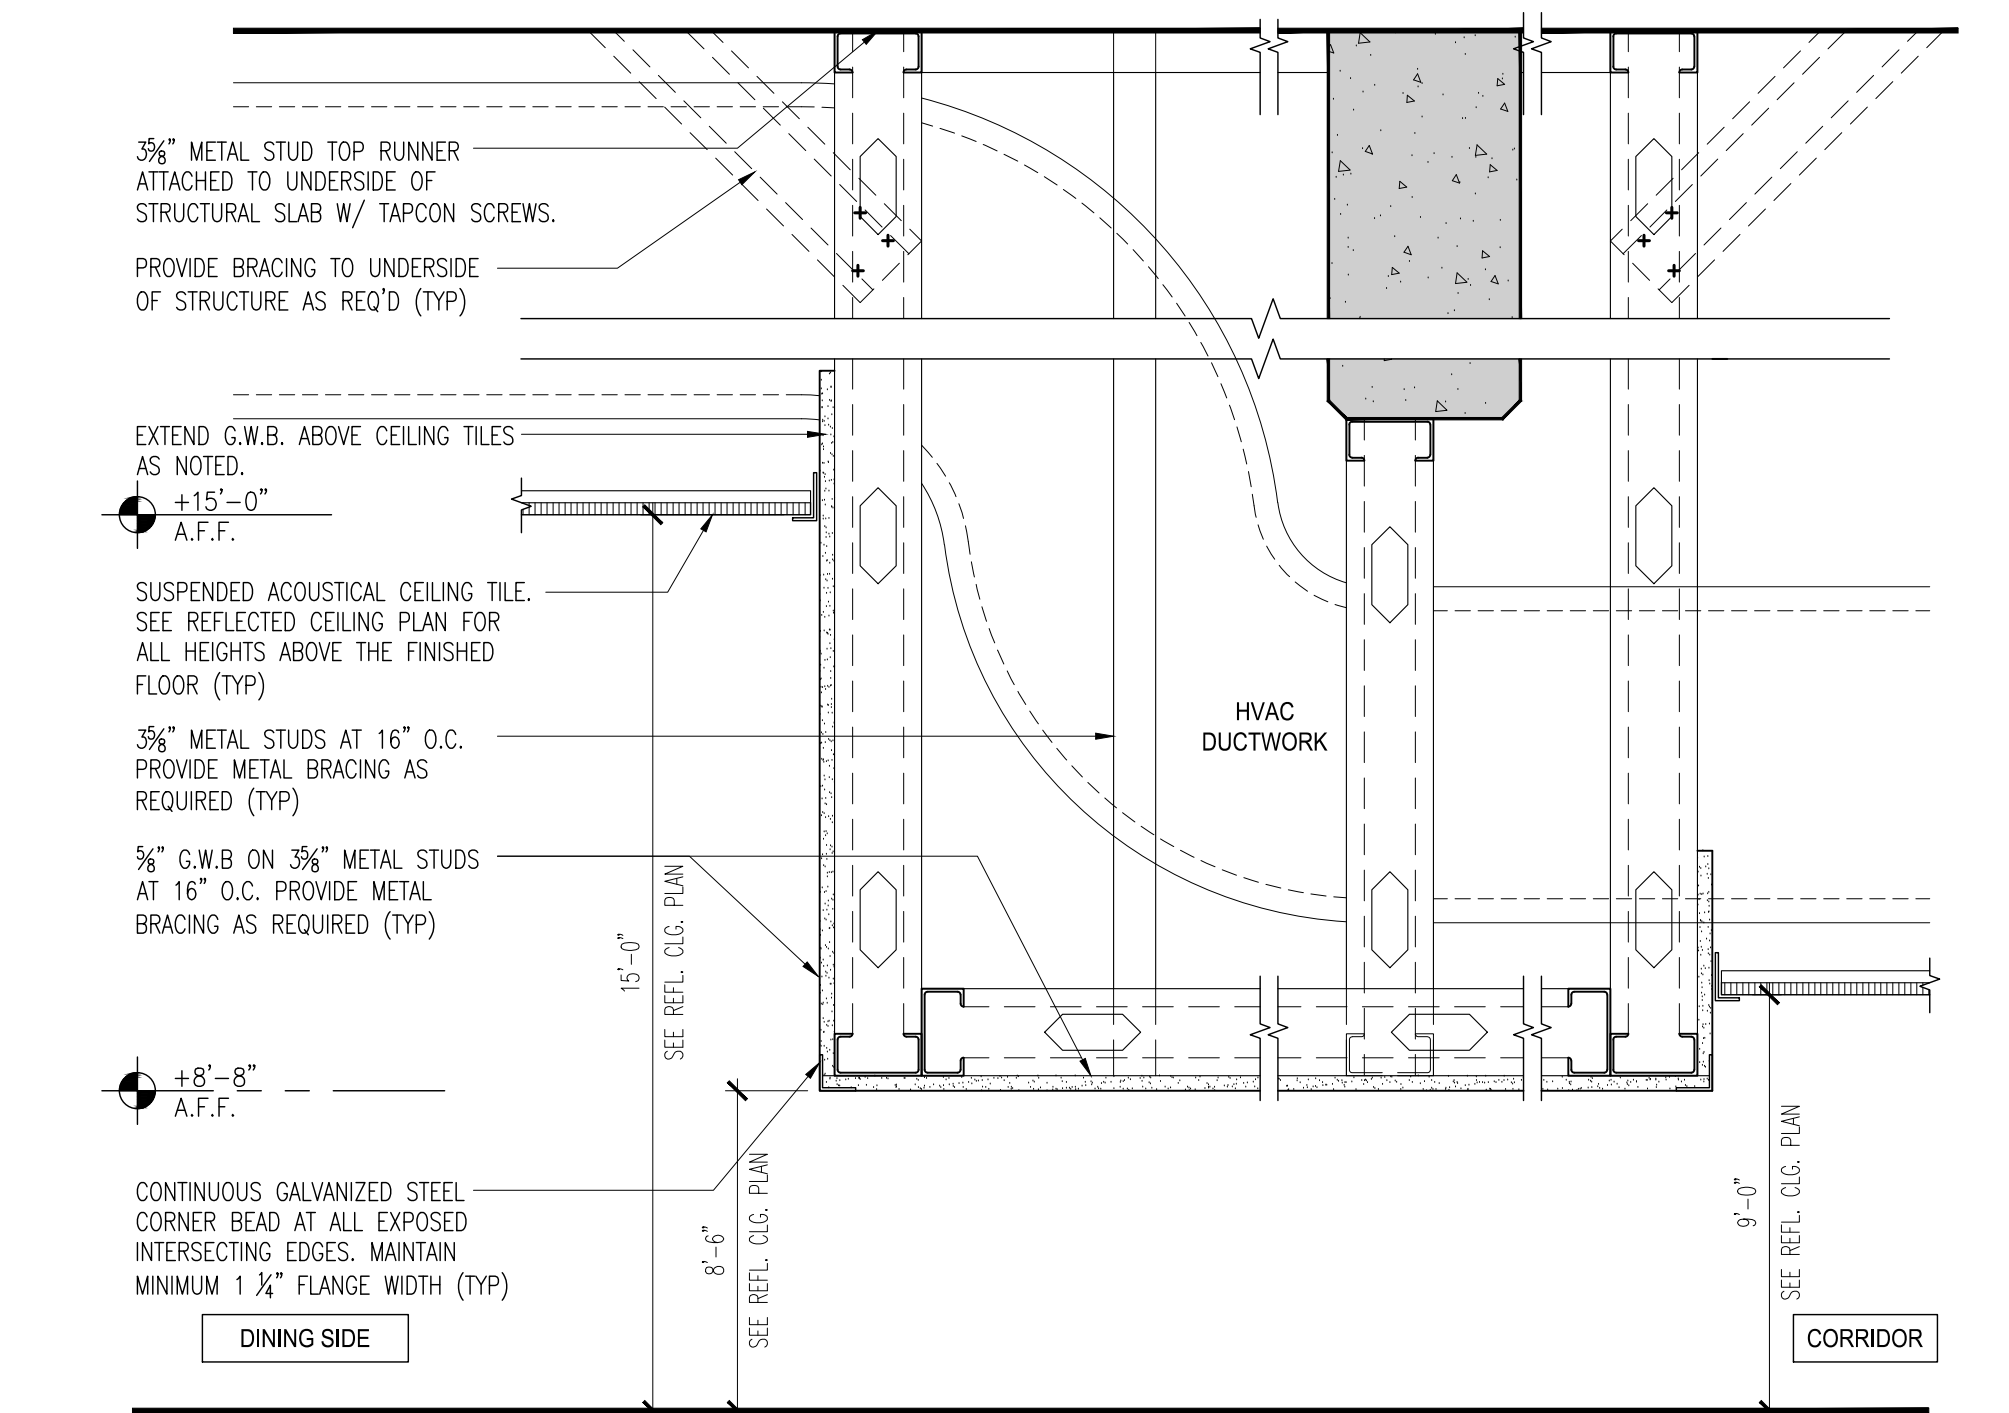


8 SOFFIT DETAIL - HVAC Ductwork (Dining)
A-330 Scale: 1-1/2" = 1'-0"

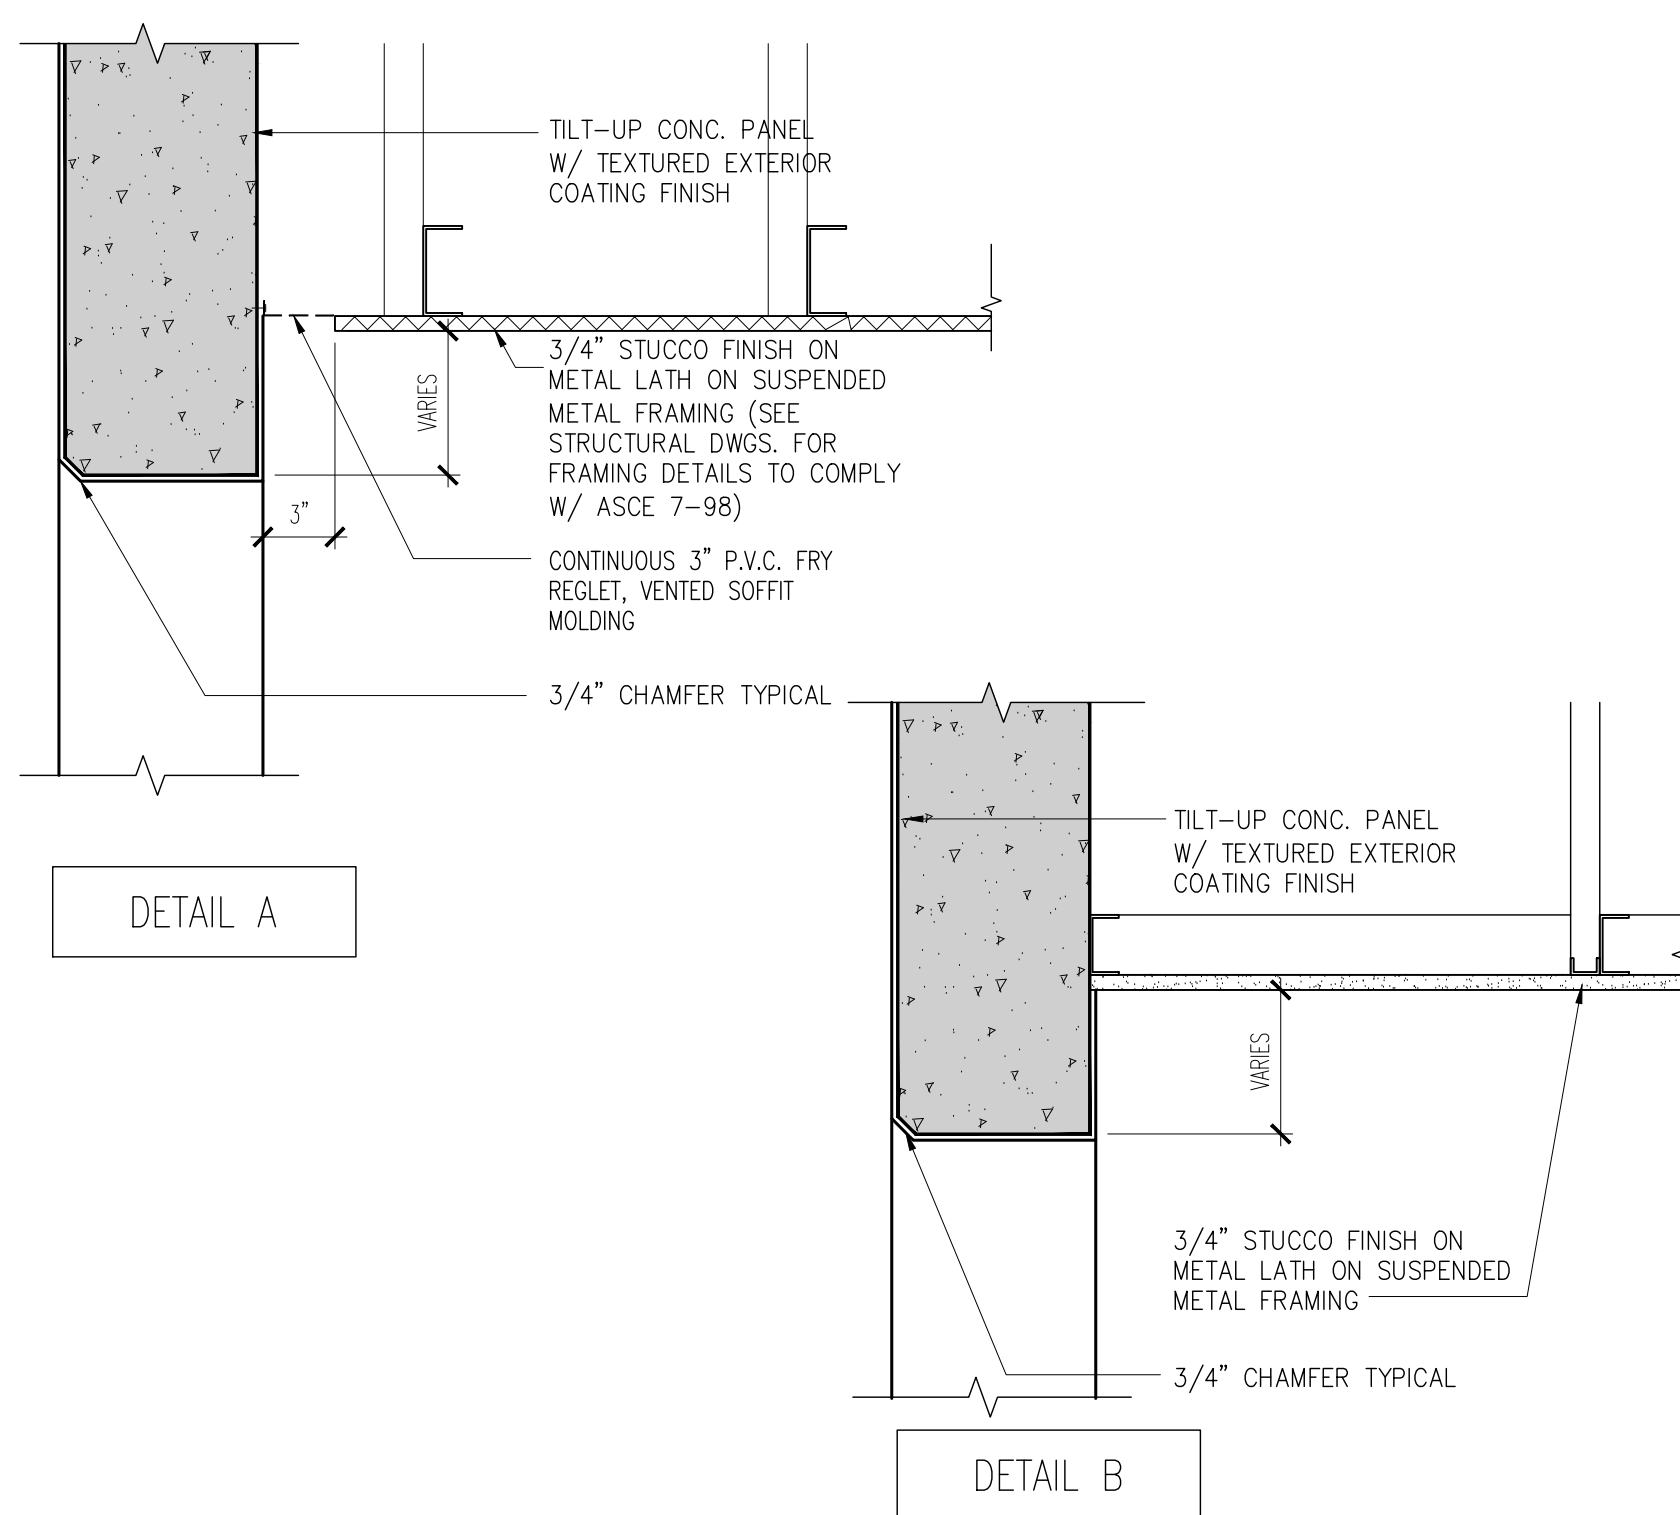

9 SOFFIT DETAIL - Exterior Entry
A-330 Scale: 1-1/2" = 1'-0"

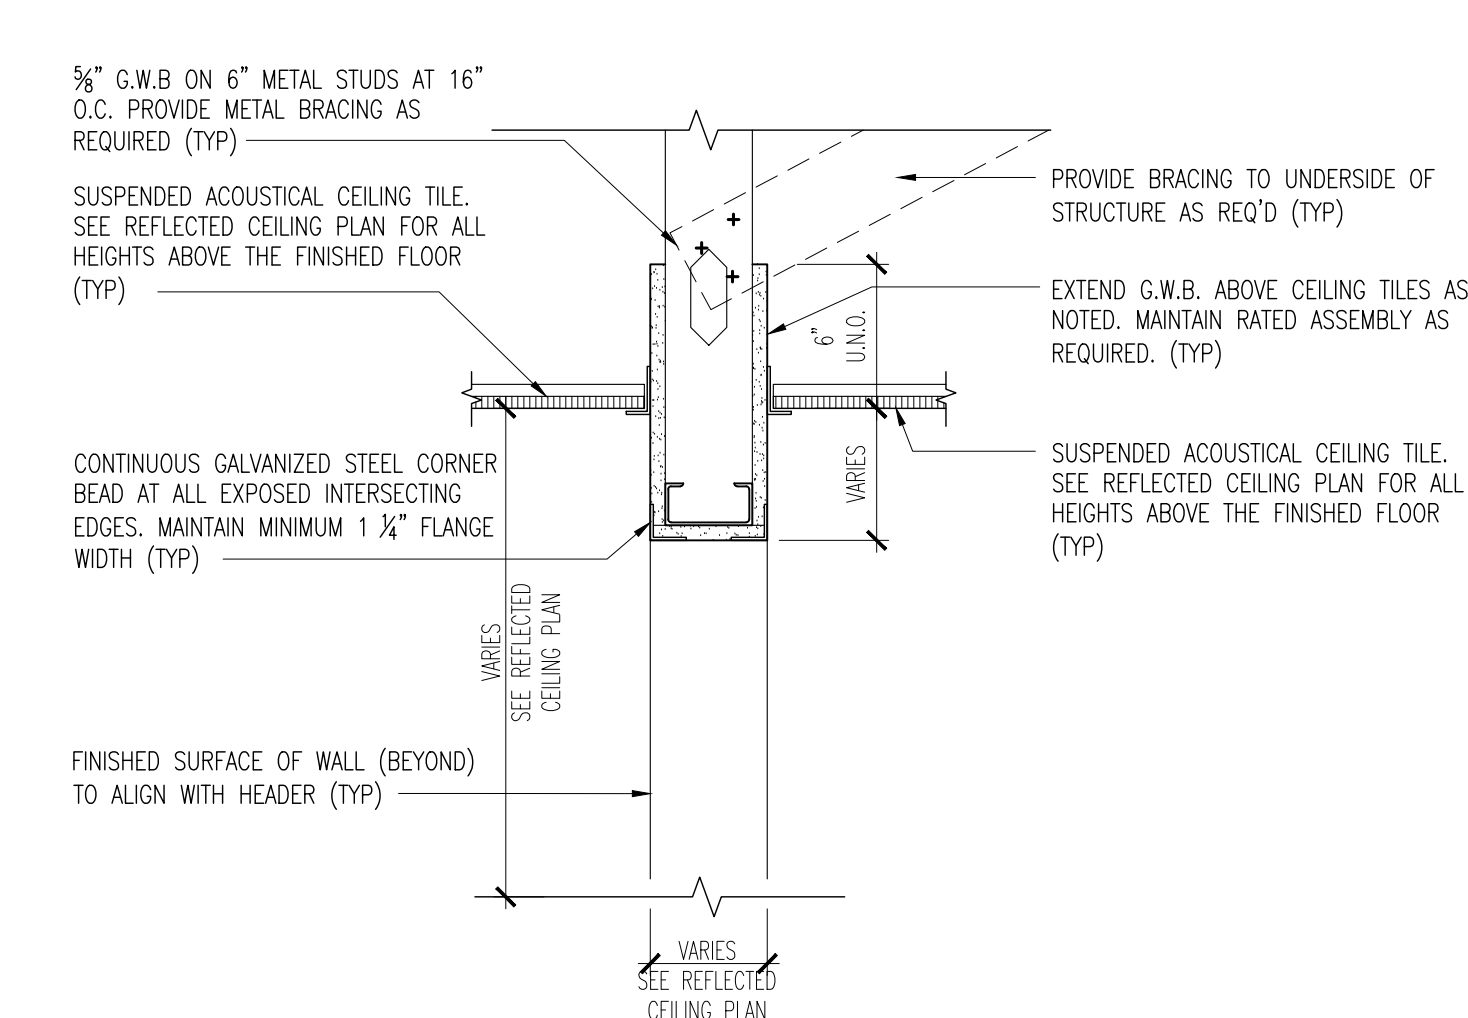

10 SOFFIT DETAIL AT CORRIDOR
A-330 Scale: 1-1/2" = 1'-0"

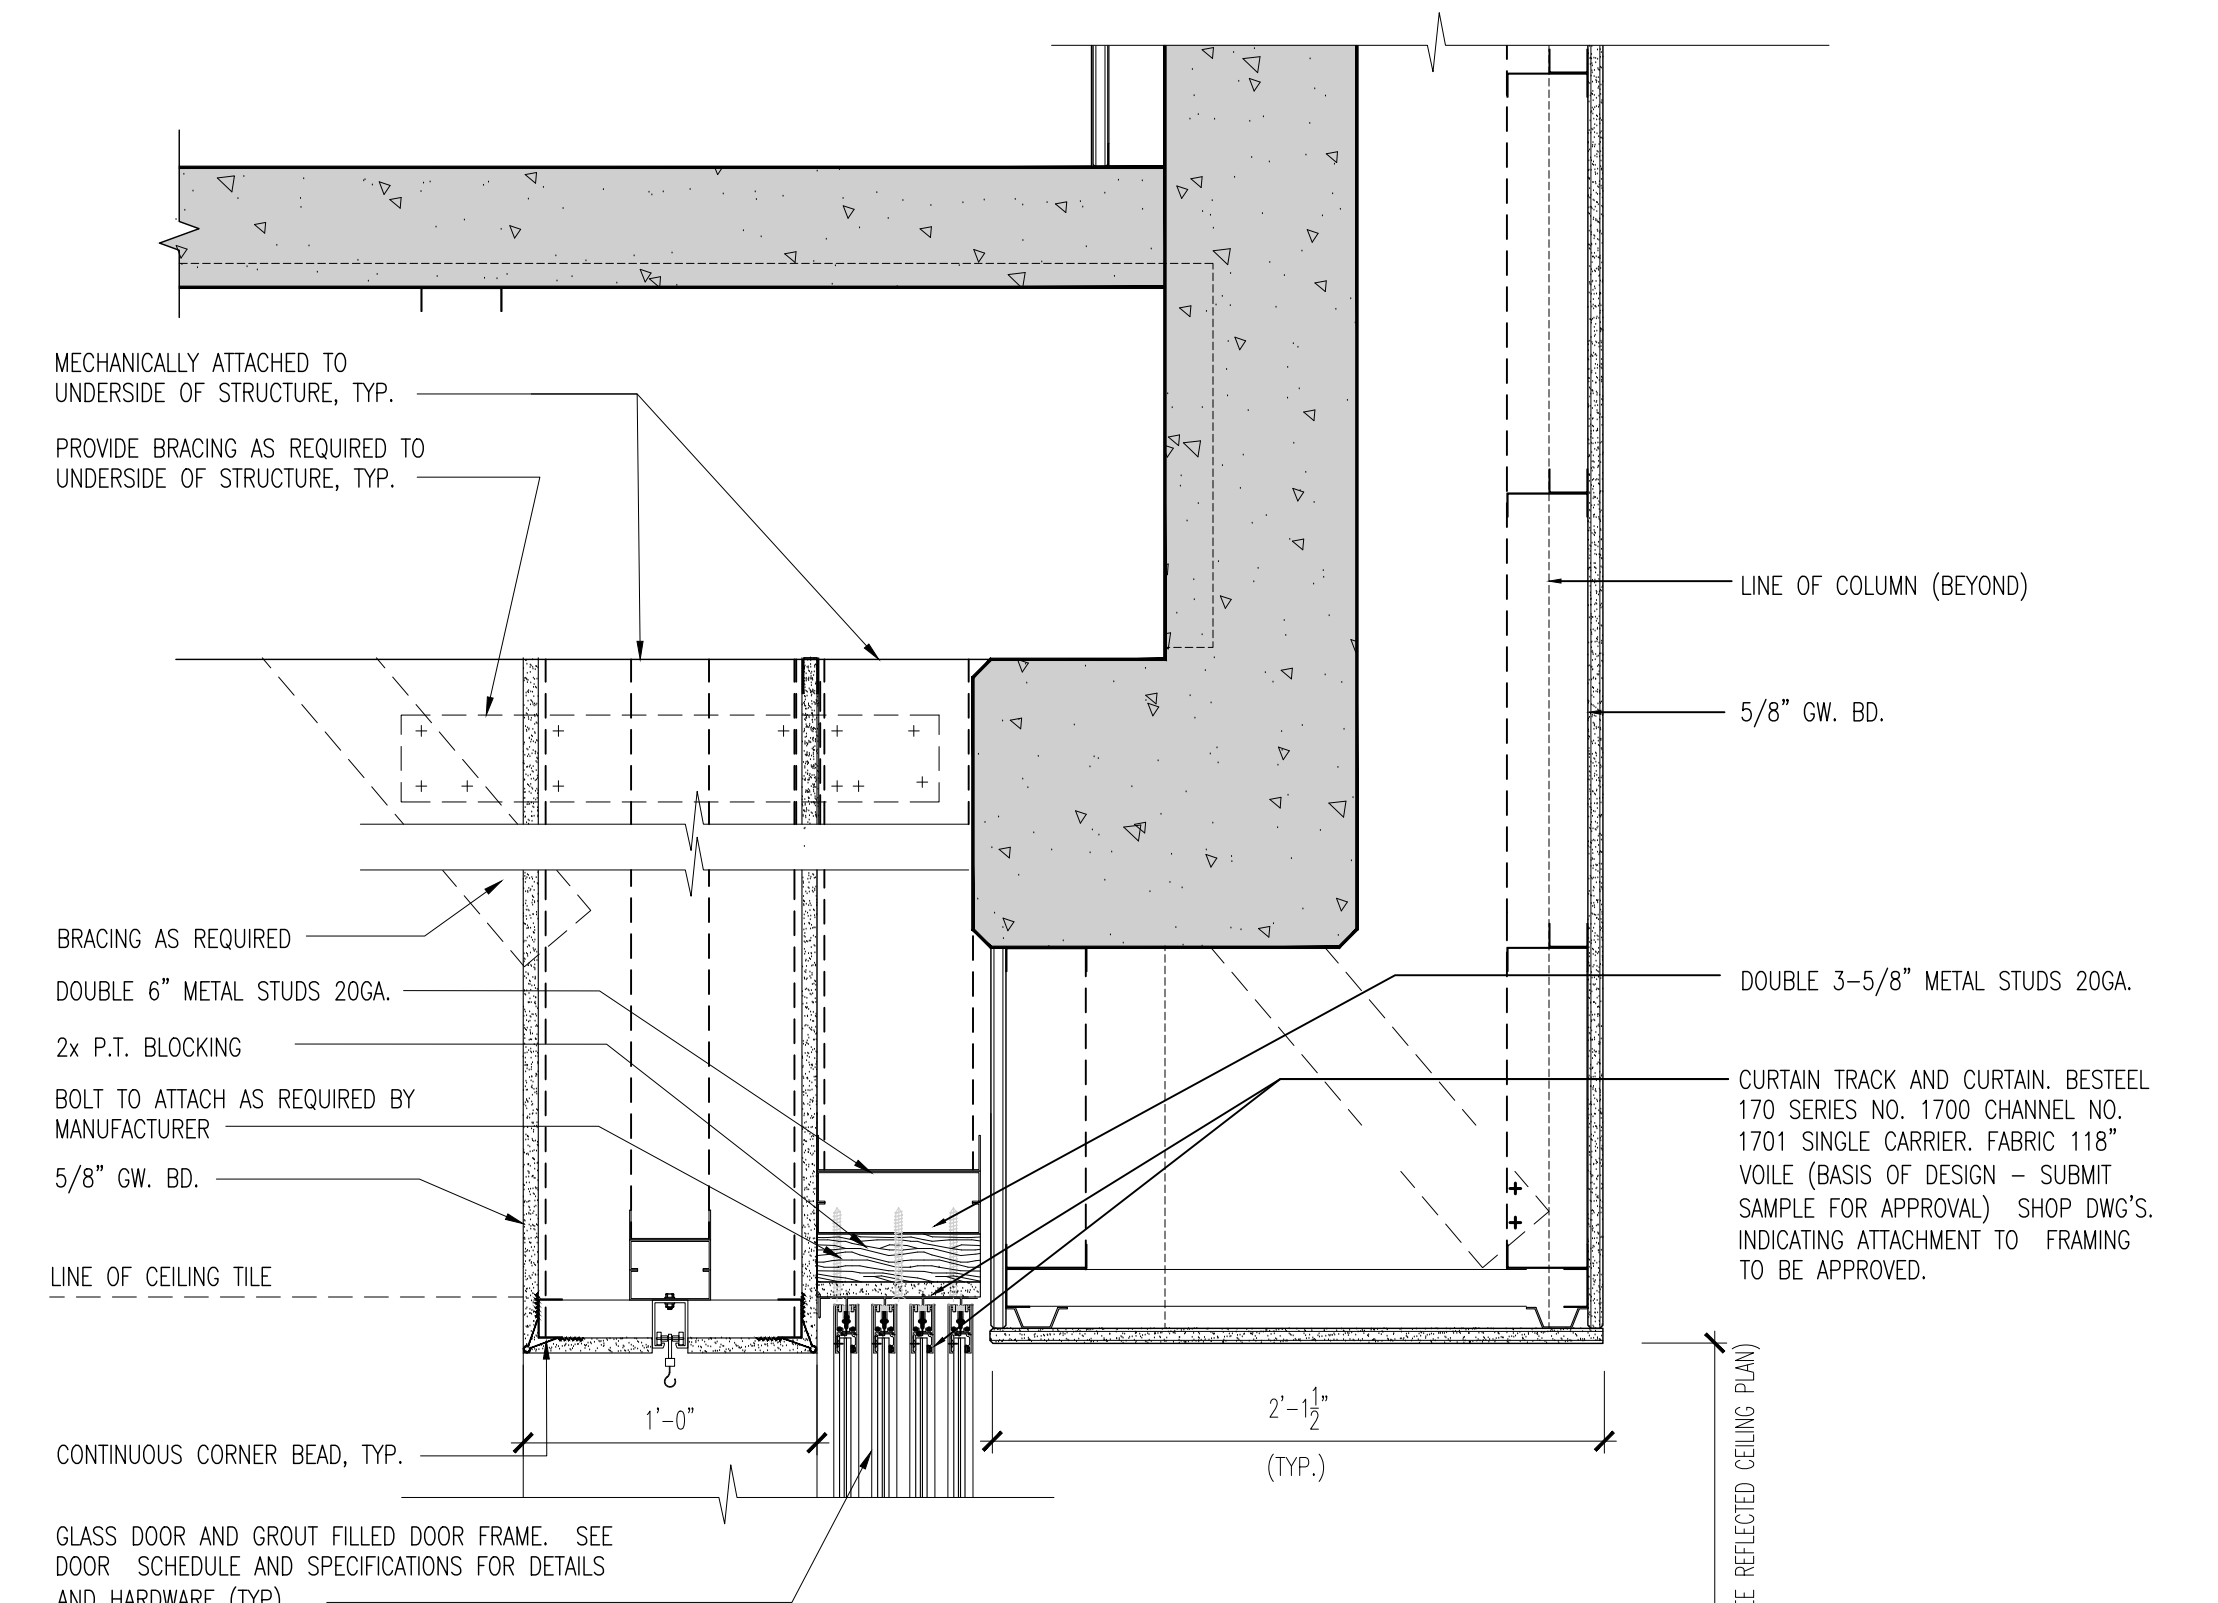

11 SOFFIT DETAIL - Sliding Doors (Dining/Music)
A-330 Scale: 1-1/2" = 1'-0"


CHECKED BY: LR	DRAWN BY: C.V.
-------------------	-------------------

CONSULTANT INFO:




NEW ELEMENTARY SCHOOL (K-5)
VENETIAN PARC WEST
SOUTHWEST 157th AVENUE and 174th STREET
MIAMI, FL. 33187
MDCPS PROJECT No. 01892600

KEY PLAN

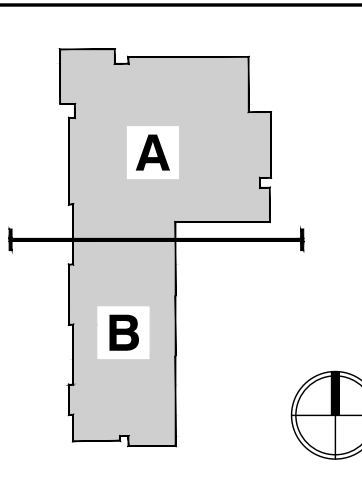

CONSULTANT INFO:

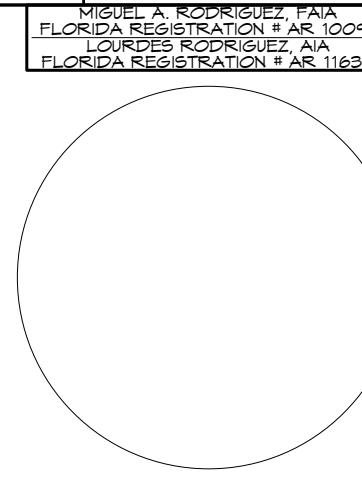


RODRIGUEZ ARCHITECTS INCORPORATED
2121 PONCE DE LEON BLVD. STE 1010
CORAL GABLES, FL. 33134
TEL: (305) 448-3373
FAX: (305) 448-3374
A A C - 0 0 1 9 3 3



REVISIONS:

DRAWING TITLE:


CEILING DETAILS
SCALE AS NOTED
ISSUE DATE: 12/16/19
PROJECT NO: 1906
SHEET: **A-330**

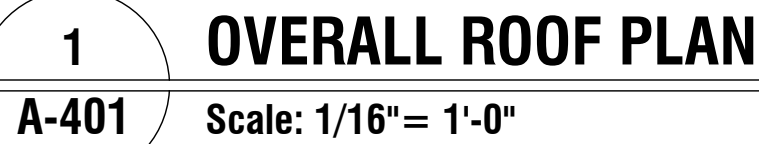


Scale: 1/16" = 1'-0"

NOTE:


GENERAL CONTRACTOR IS RESPONSIBLE TO COORDINATE REQUIRED DIMENSIONS TO PROVIDE PROPER MECHANICAL EQUIPMENT CLEARANCES.

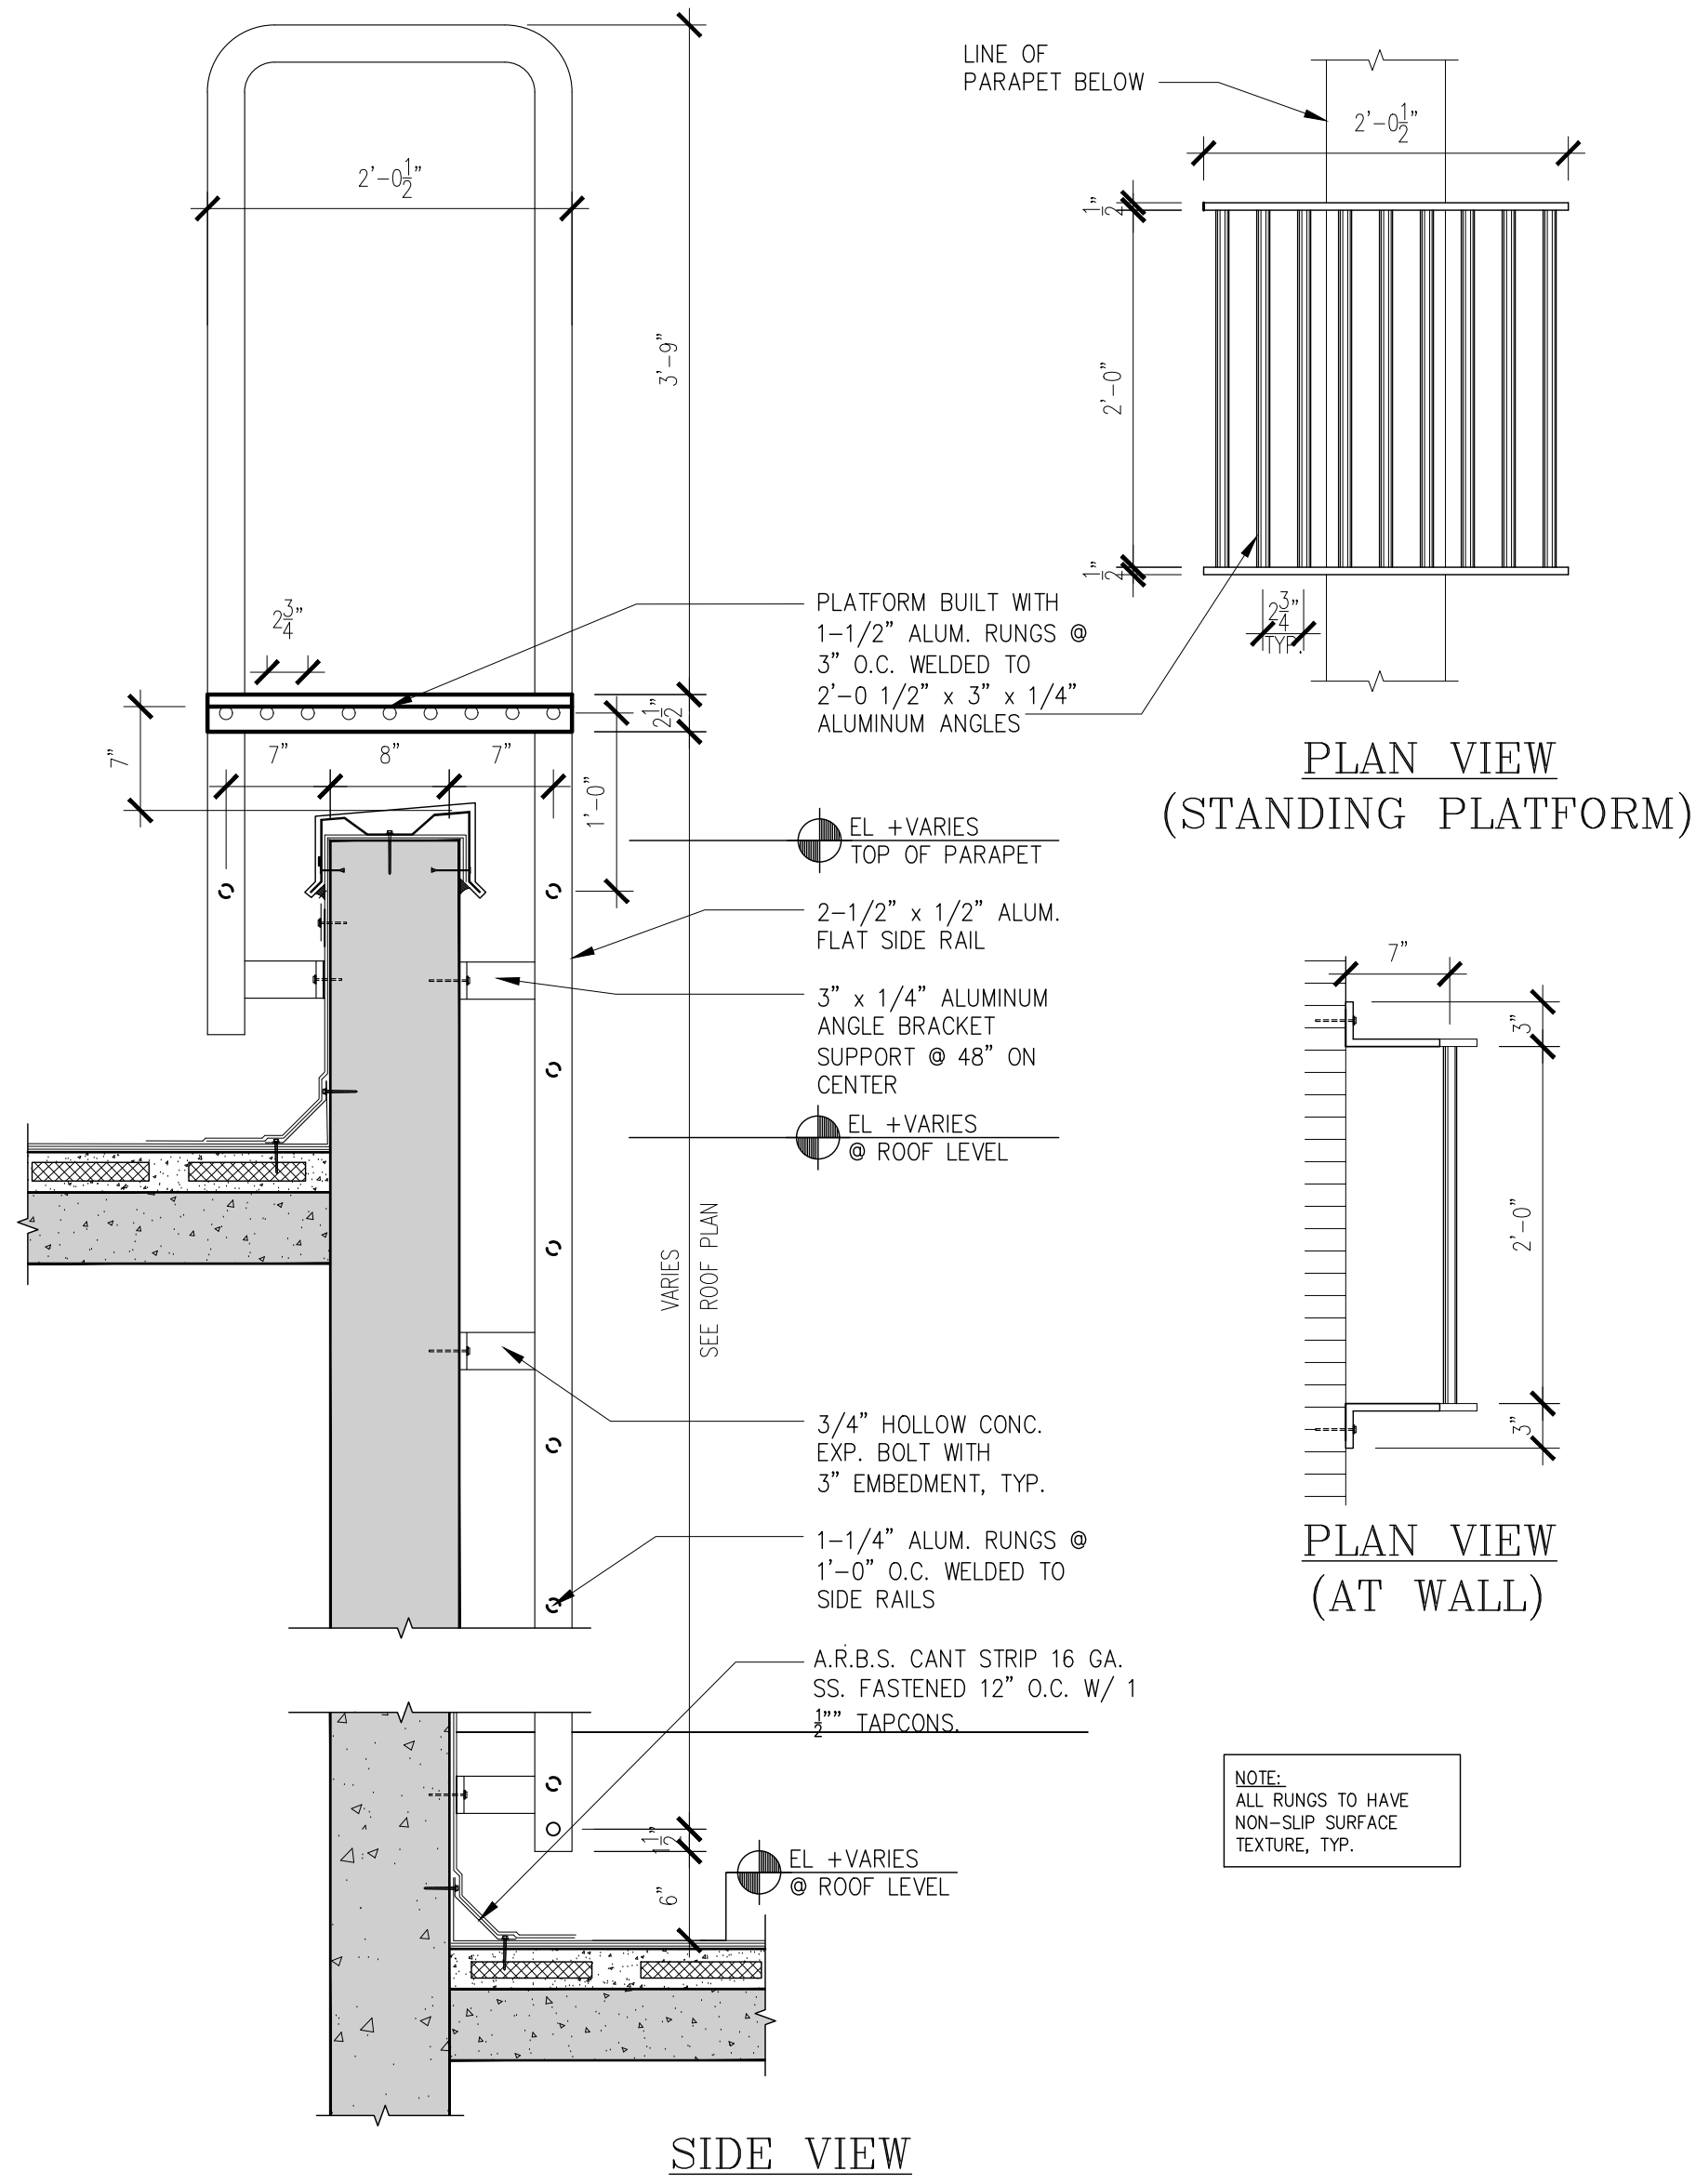


1 ROOF LADDER DETAIL
A-420 Scale: 1" = 1'-0"

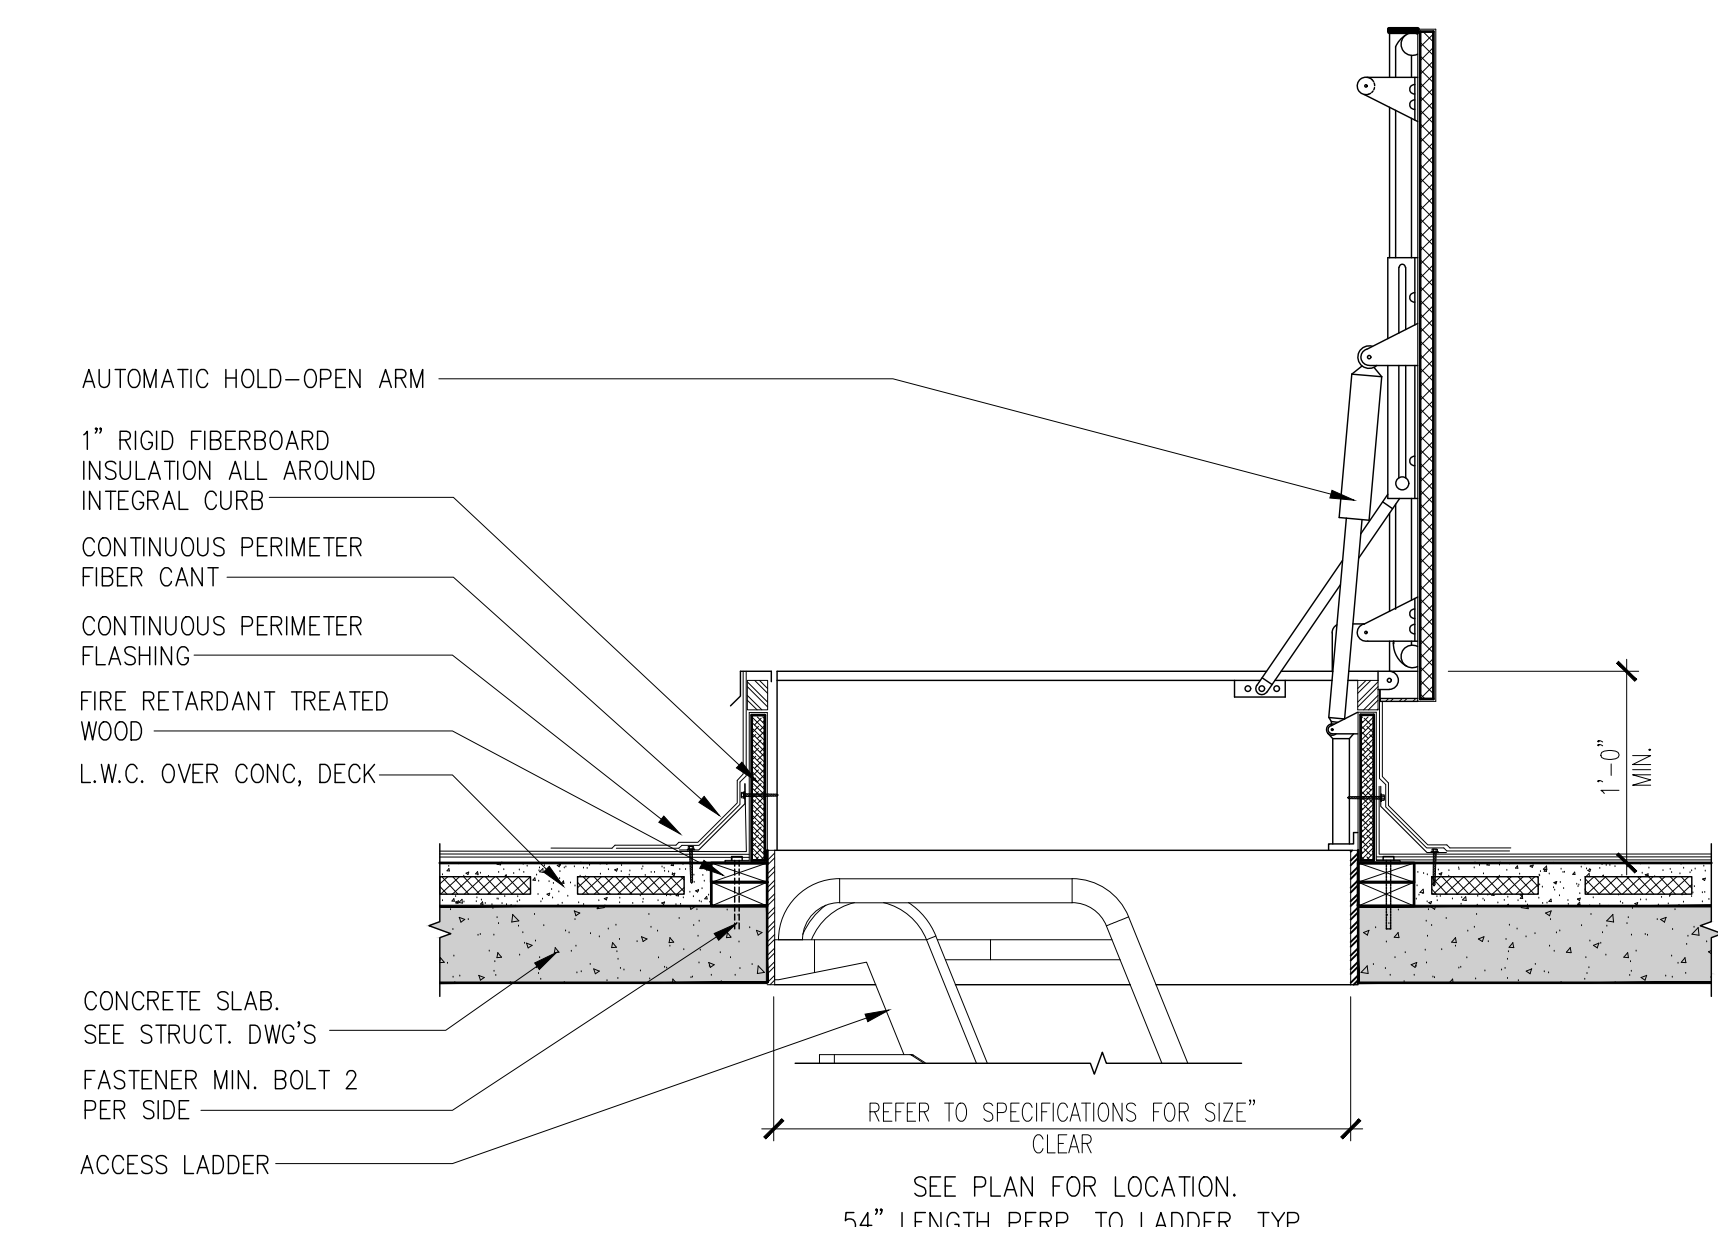


3 ROOF HATCH DETAIL
A-420 Scale: 1" = 1'-0"

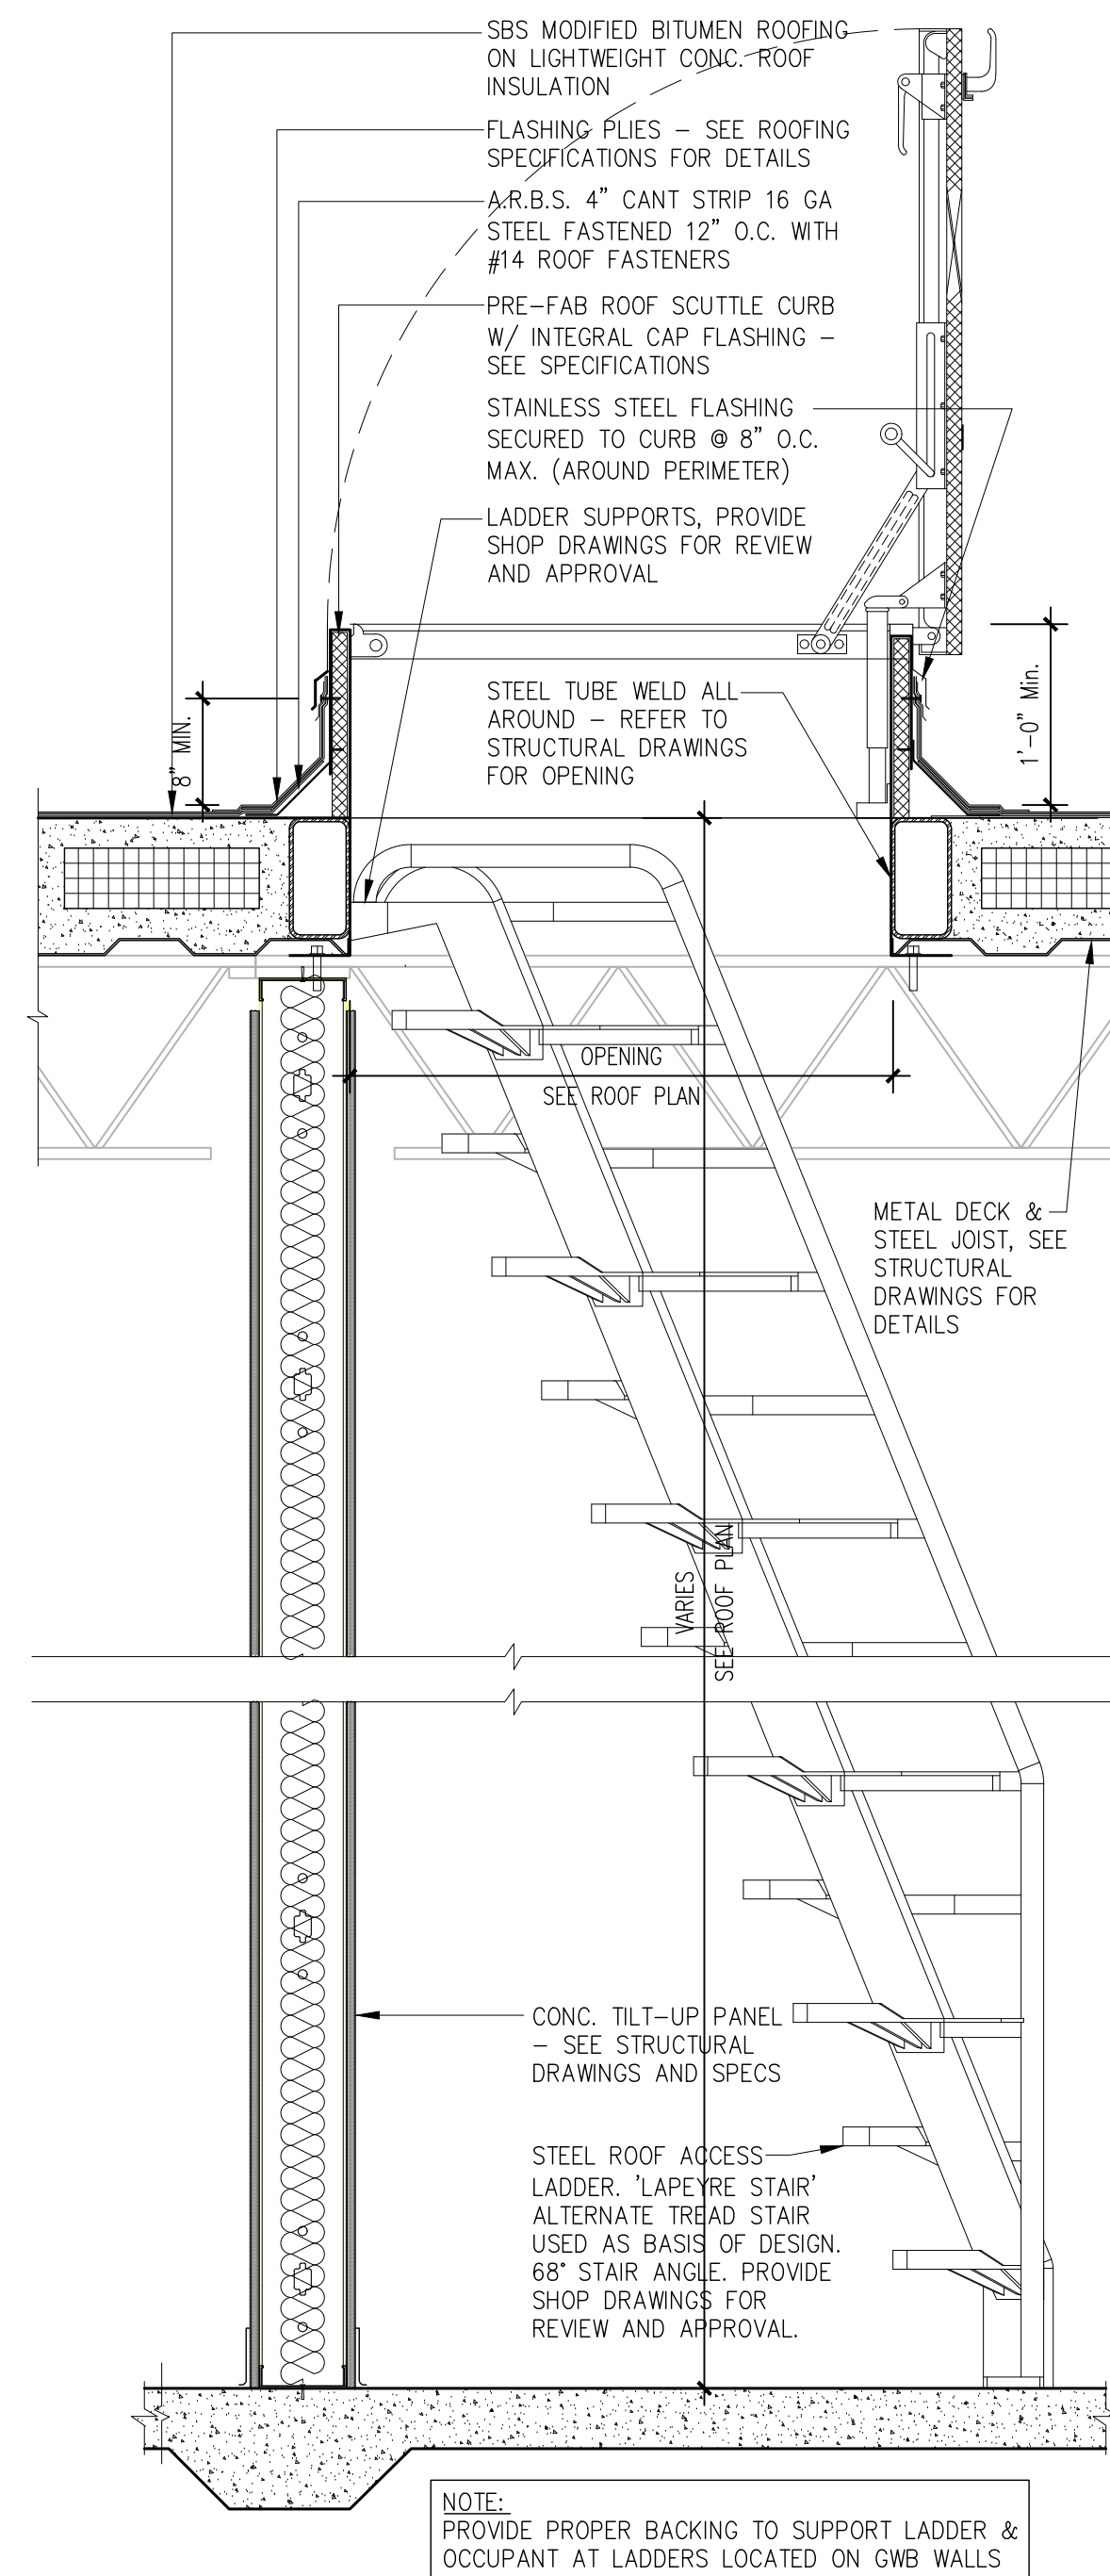


2 ROOF ACCESS LADDER DETAIL
A-420 Scale: 1" = 1'-0"

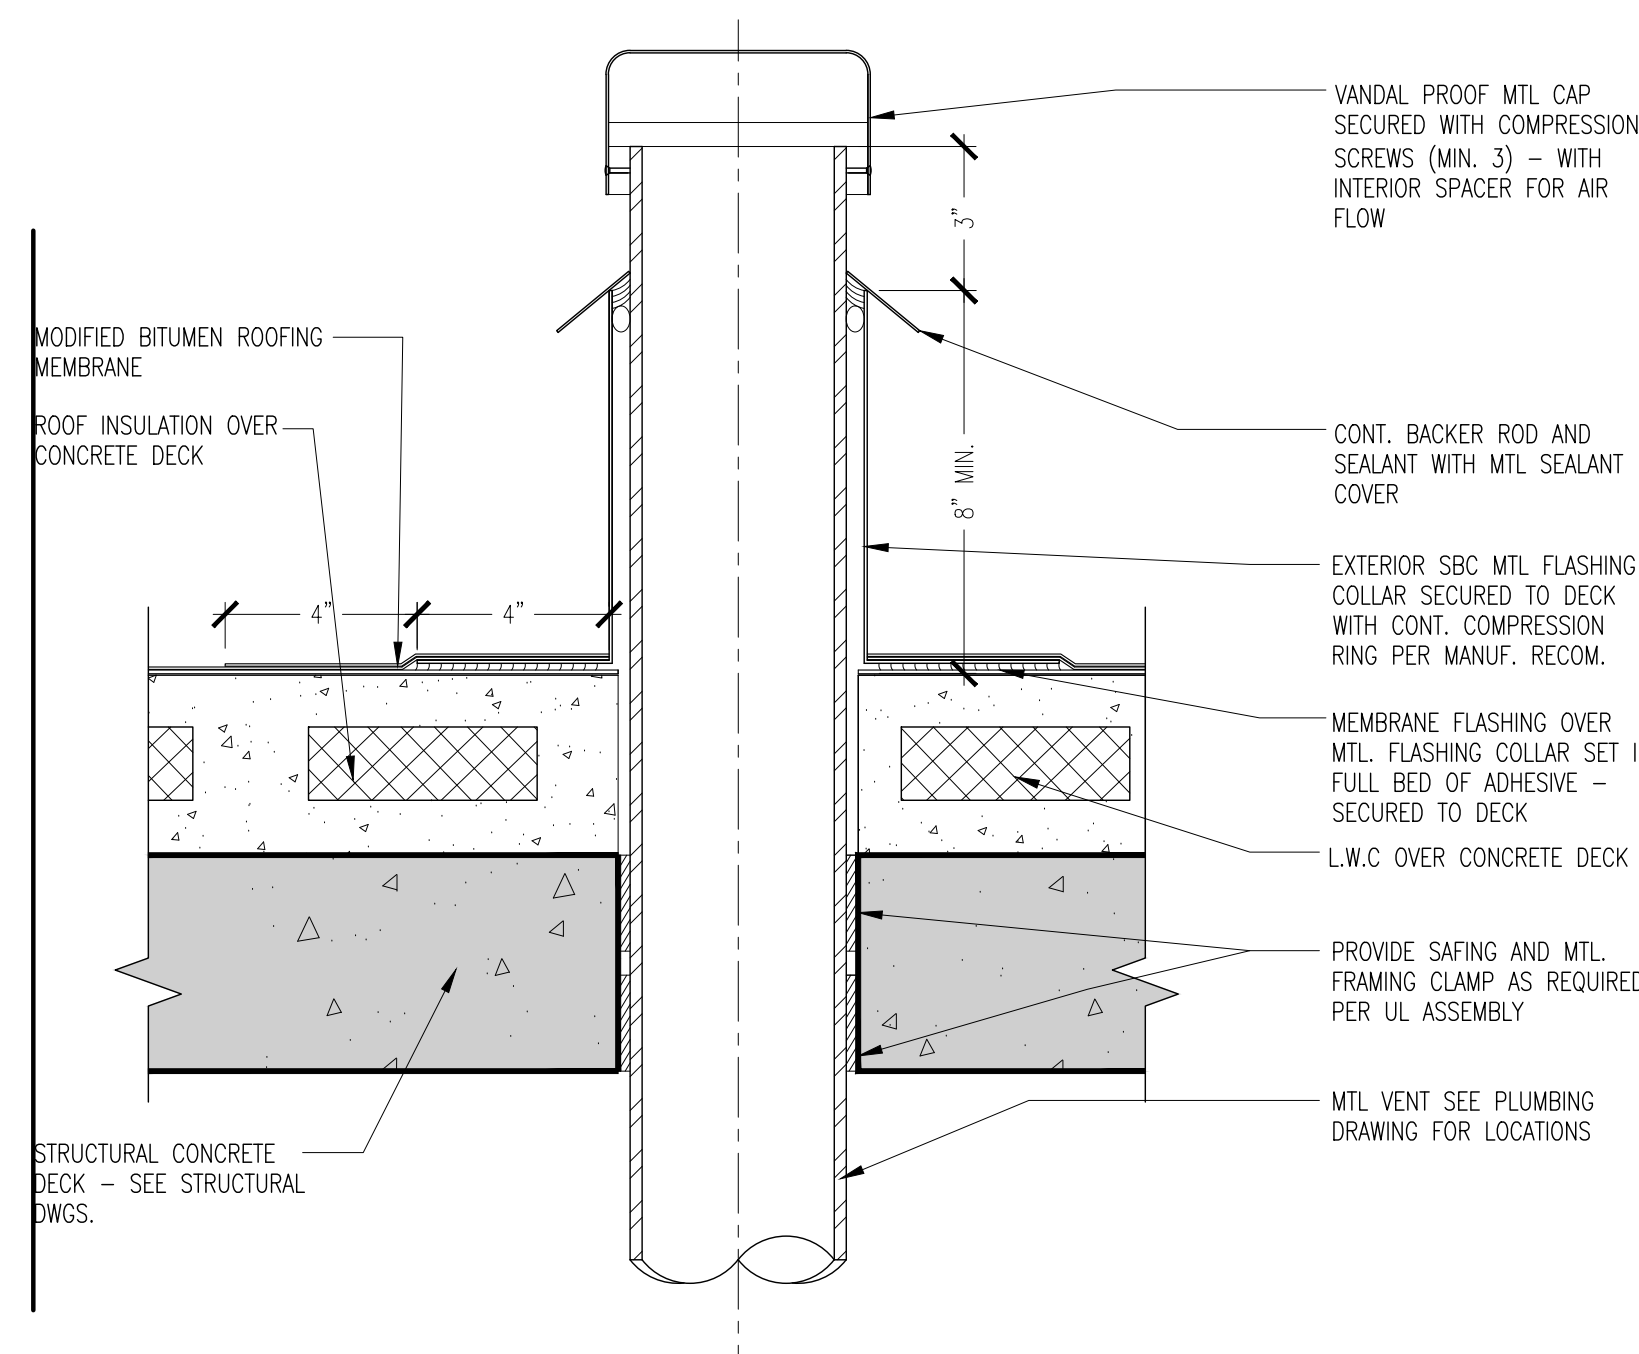


4 PIPE PENETRATION DETAIL - TYPICAL
A-420 Scale: 1 1/2" = 1'-0"

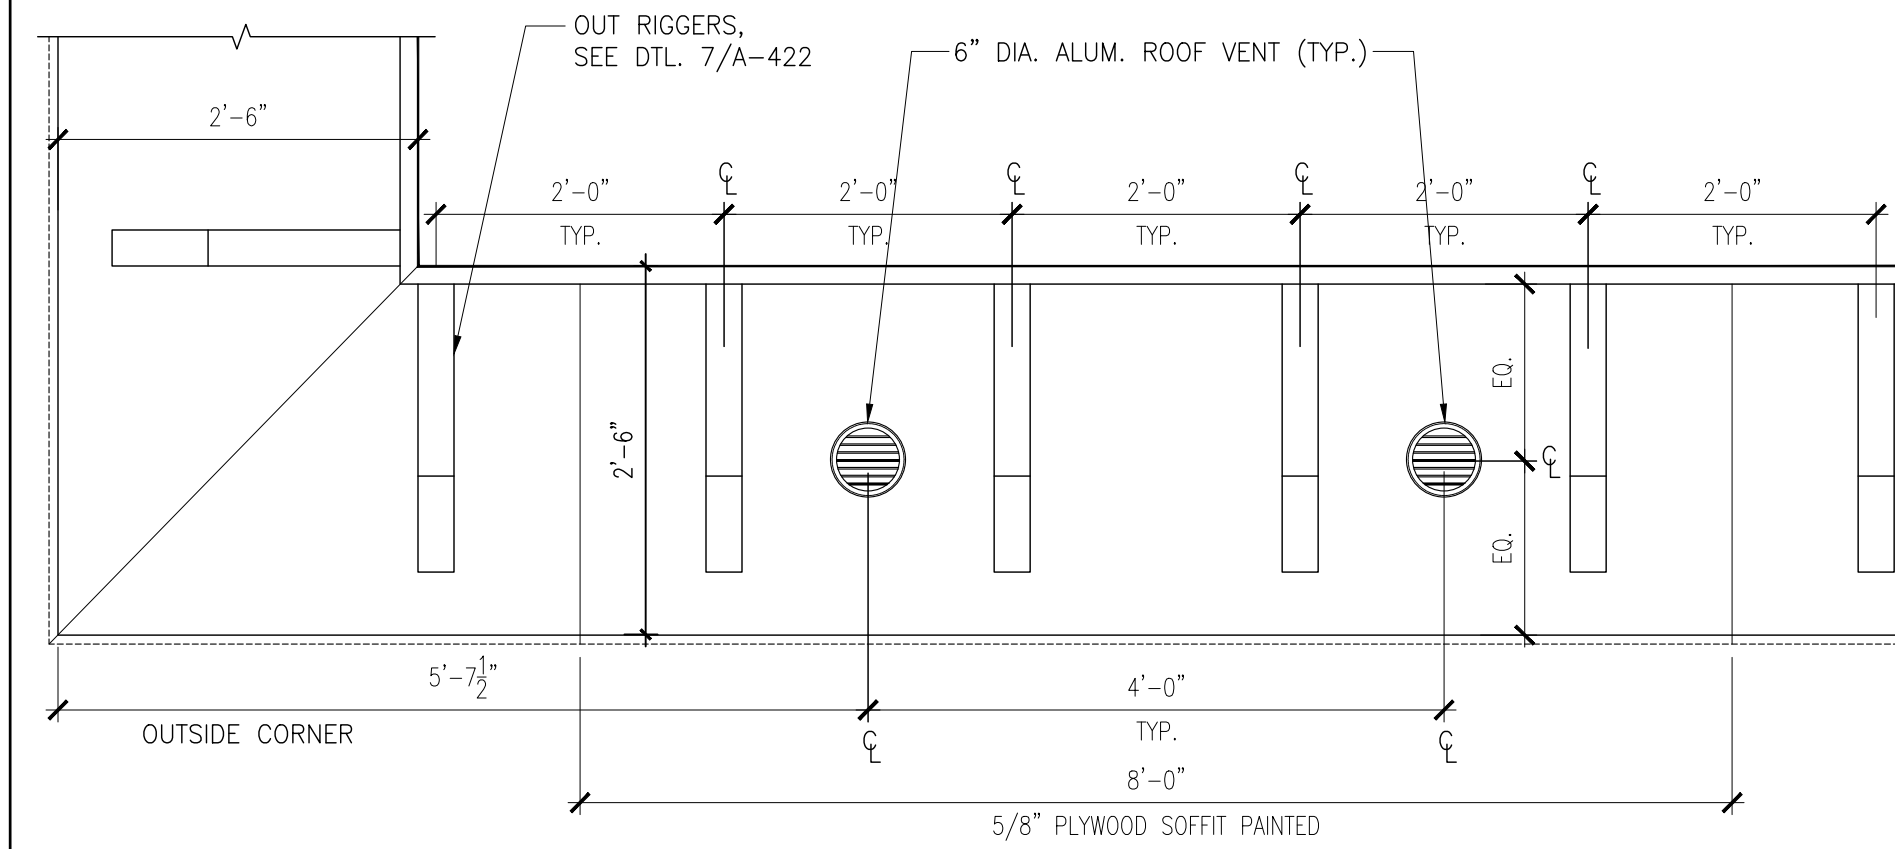


6 BUILDING OVERHANG REFLECTED CEILING DETAIL @ STAIR TOWERS
A-420 Scale: 3/4" = 1'-0"

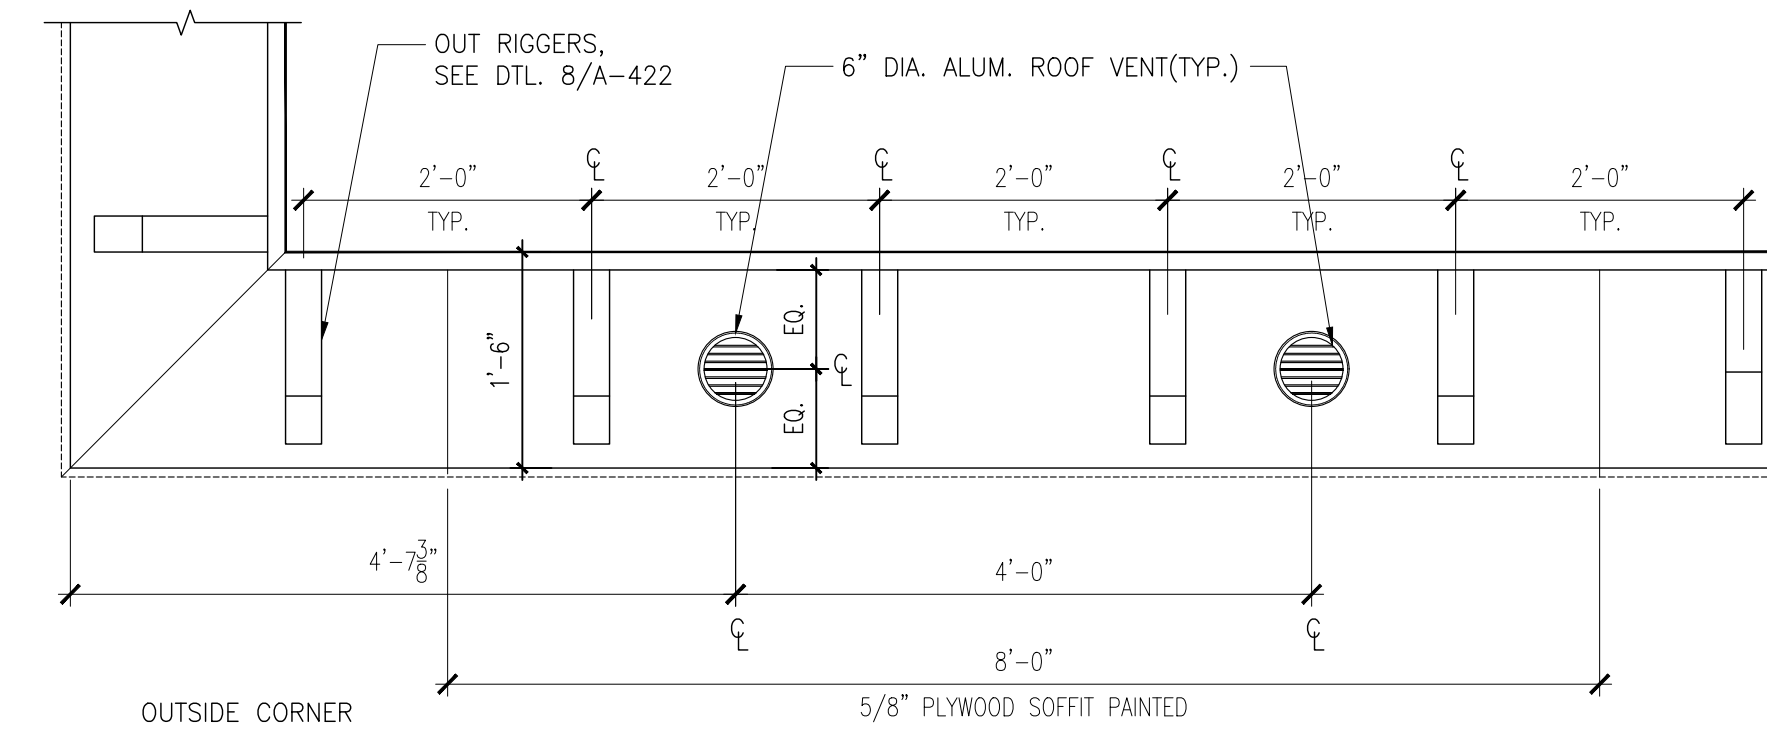


7 BUILDING OVERHANG REFLECTED CEILING DETAIL @ MAIN/SECONDARY ENTRANCE
A-420 Scale: 3/4" = 1'-0"

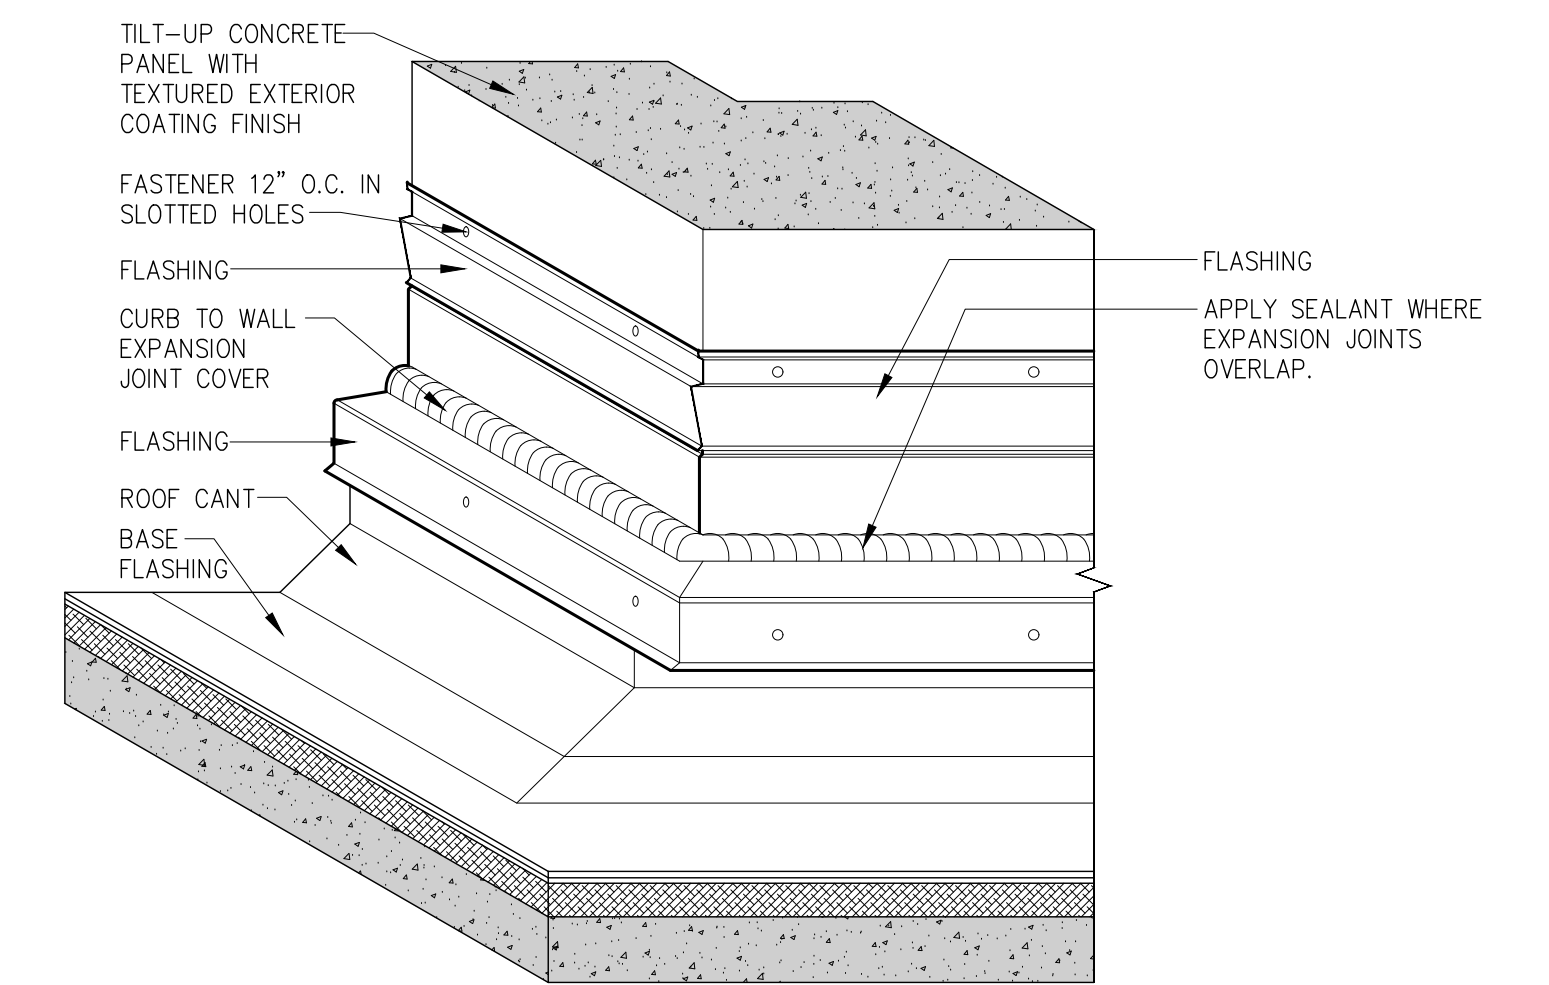

8 EXPANSION JOINT DETAIL
A-420 Scale: 1" = 1'-0"

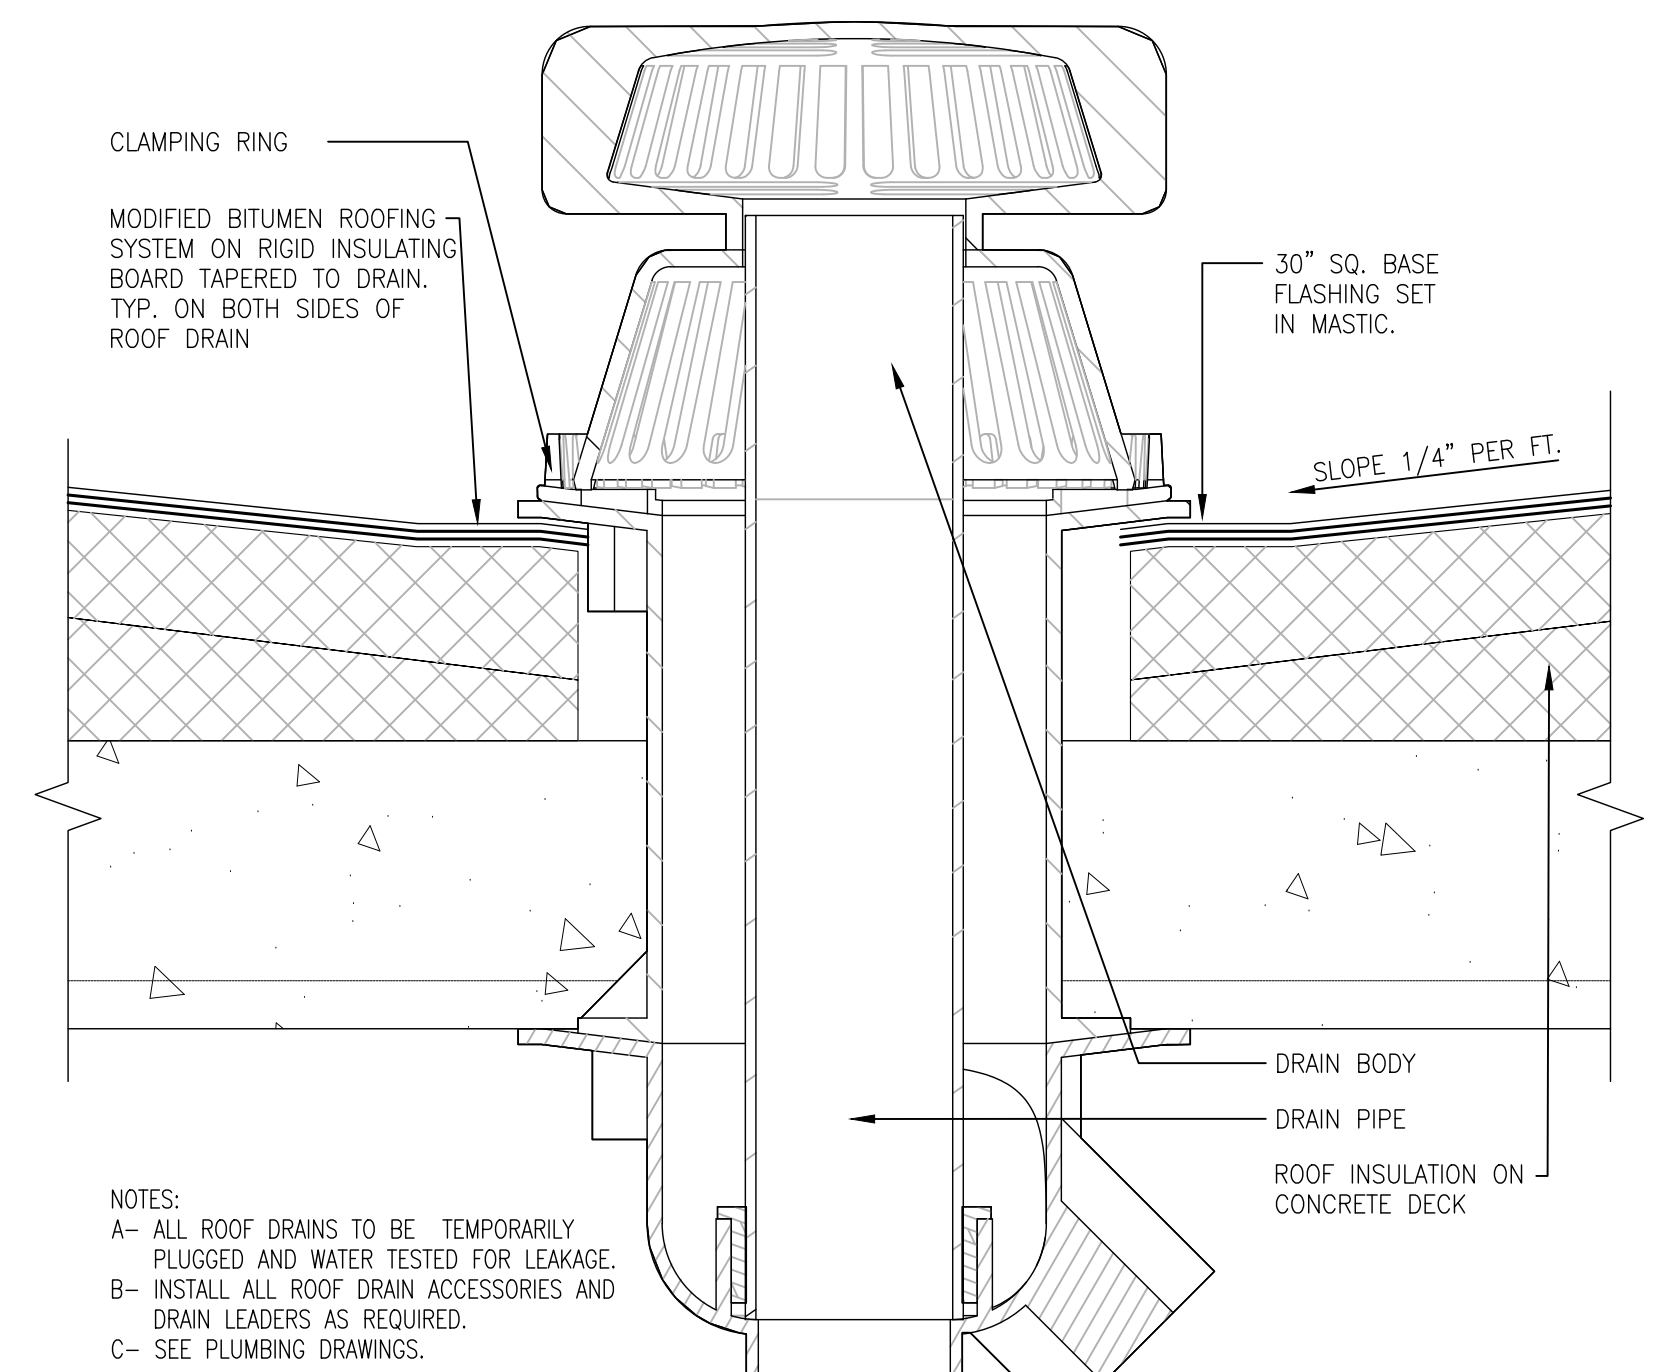


9 COMBINATION ROOF DRAIN
A-420 Scale: 3" = 1'-0"

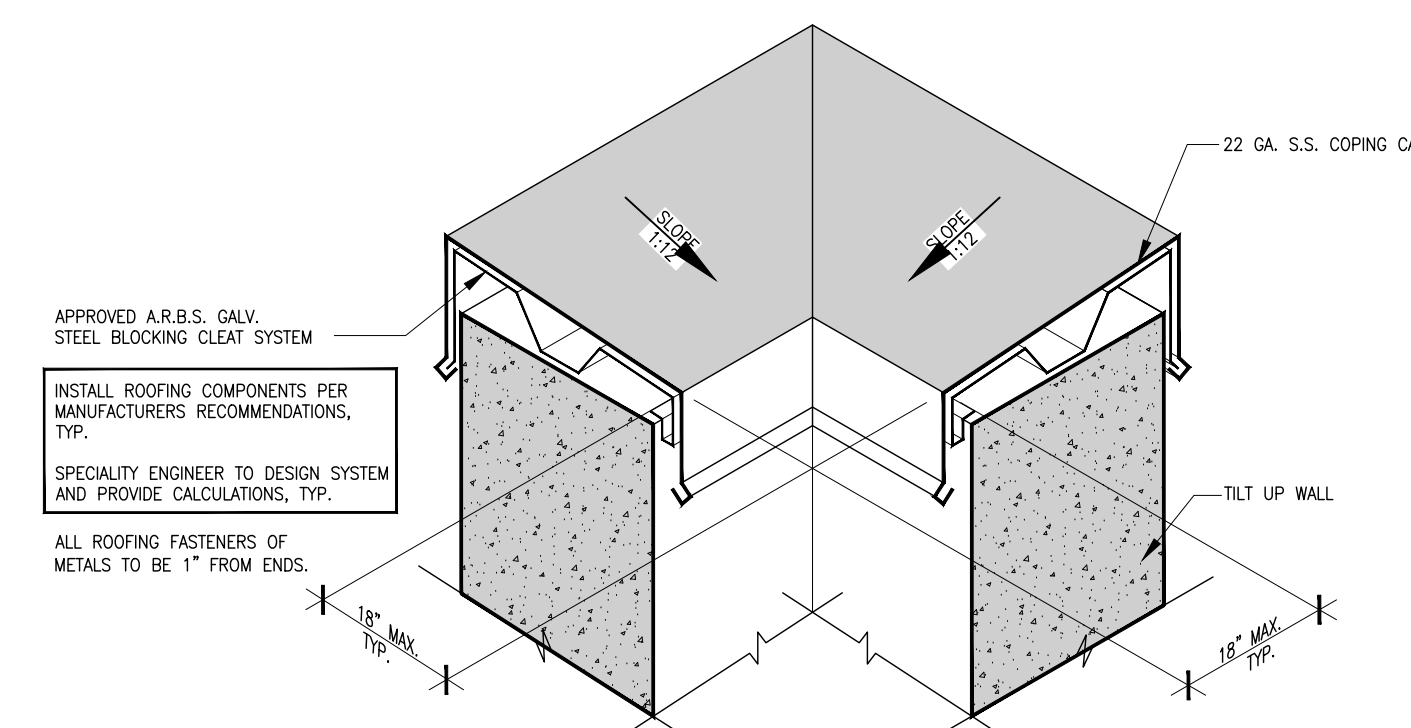

10 PARAPET CAP CORNER
A-420 Scale: N.T.S.


KEY NOTES	GENERAL NOTES	
"RD": ROOF DRAIN	1. RAIN WATER CALCULATIONS BASED ON A 5" PER HOUR RATE OF RAINFALL. CODE ONLY REQUIRES 4.5" PER FIGURE 1106.1, FBC 2014	7. COORDINATE ALL HIGH AND LOW POINTS OF CONCRETE SLAB WITH STRUCTURAL DRAWINGS.
"CH": COLLECTOR HEAD W/ LEADER		
"L": LEADER		
"SC": SCUPPER		
"OS": OVERFLOW SCUPPER		
"SB": SPLASH BLOCK	2. ALL LEADERS "L" SHALL BE SIZED TO MATCH THE "CH" SPECIFIED ABOVE	8. SEE SITE PLAN FOR COORDINATION/LOCATION OF ALL ALUMINUM CANOPIES.
	3. ALL OVERFLOW SCUPPERS (OS) SHALL BE SET NOT LESS THAN 2" NOR MORE THAN 4" ABOVE THE ROOF LINE	9. ALL ROOF FLASHING, GUTTERS, CATCHBOX, DOWNSPOUTS, LEADERS, STRAPS AND CORING SHALL BE STAINLESS STEEL.
	4. SEE DETAILS FOR COLLECTOR HEAD (CH), AND OVERFLOW (OS) SCUPPER SPECIFIED ABOVE.	10. COORDINATE LOCATION OF ALL ROOF WALK PADS WITH MECHANICAL DRAWINGS AND OWNER. WALK PADS SHALL BE DIFFERENT COLOR FROM FINAL ROOF SURFACE TO CLEARLY DELINEATE TRAFFIC AREAS.
	5. ALL STORM LEADERS SHALL BE CONNECTED TO UNDERGROUND STORM WATER COLLECTION/DISPOSAL SYSTEM. REFER TO CIVIL DRAWINGS FOR LOCATION, SIZE & DETAILS.	11. ALL WOOD COMPONENTS TO BE FIRE RETARDANT WOOD.
	6. REFER TO STRUCTURAL DRAWINGS FOR HEIGHT OF ROOF DECK AND COORDINATION OF DRAIN/SCUPPER OPENINGS.	12. PRICING TO INCLUDE OPTIONS FOR BOTH RIGID BOARD INSULATION AND LIGHTWEIGHT INSULATING CONCRETE FOR BASE.

*** SEE DETAILS FOR MORE INFORMATION ON OVERFLOW SCUPPERS

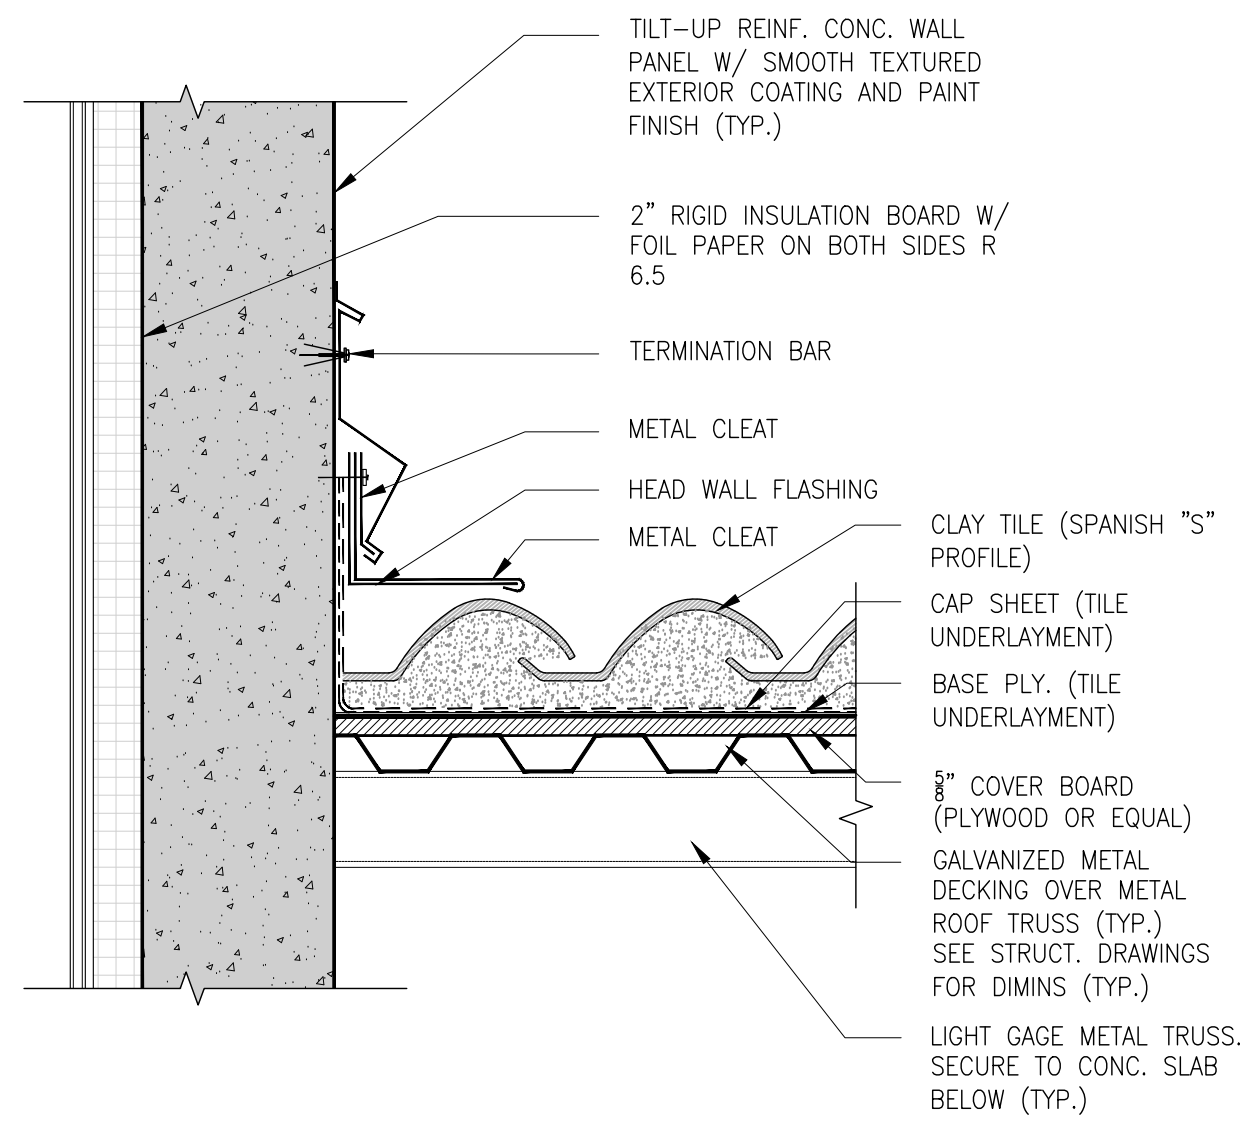


1 TILT WALL FLASHING DETAIL @ MANSARD ROOF

A-421 Scale: 1 1/2" = 1'-0"

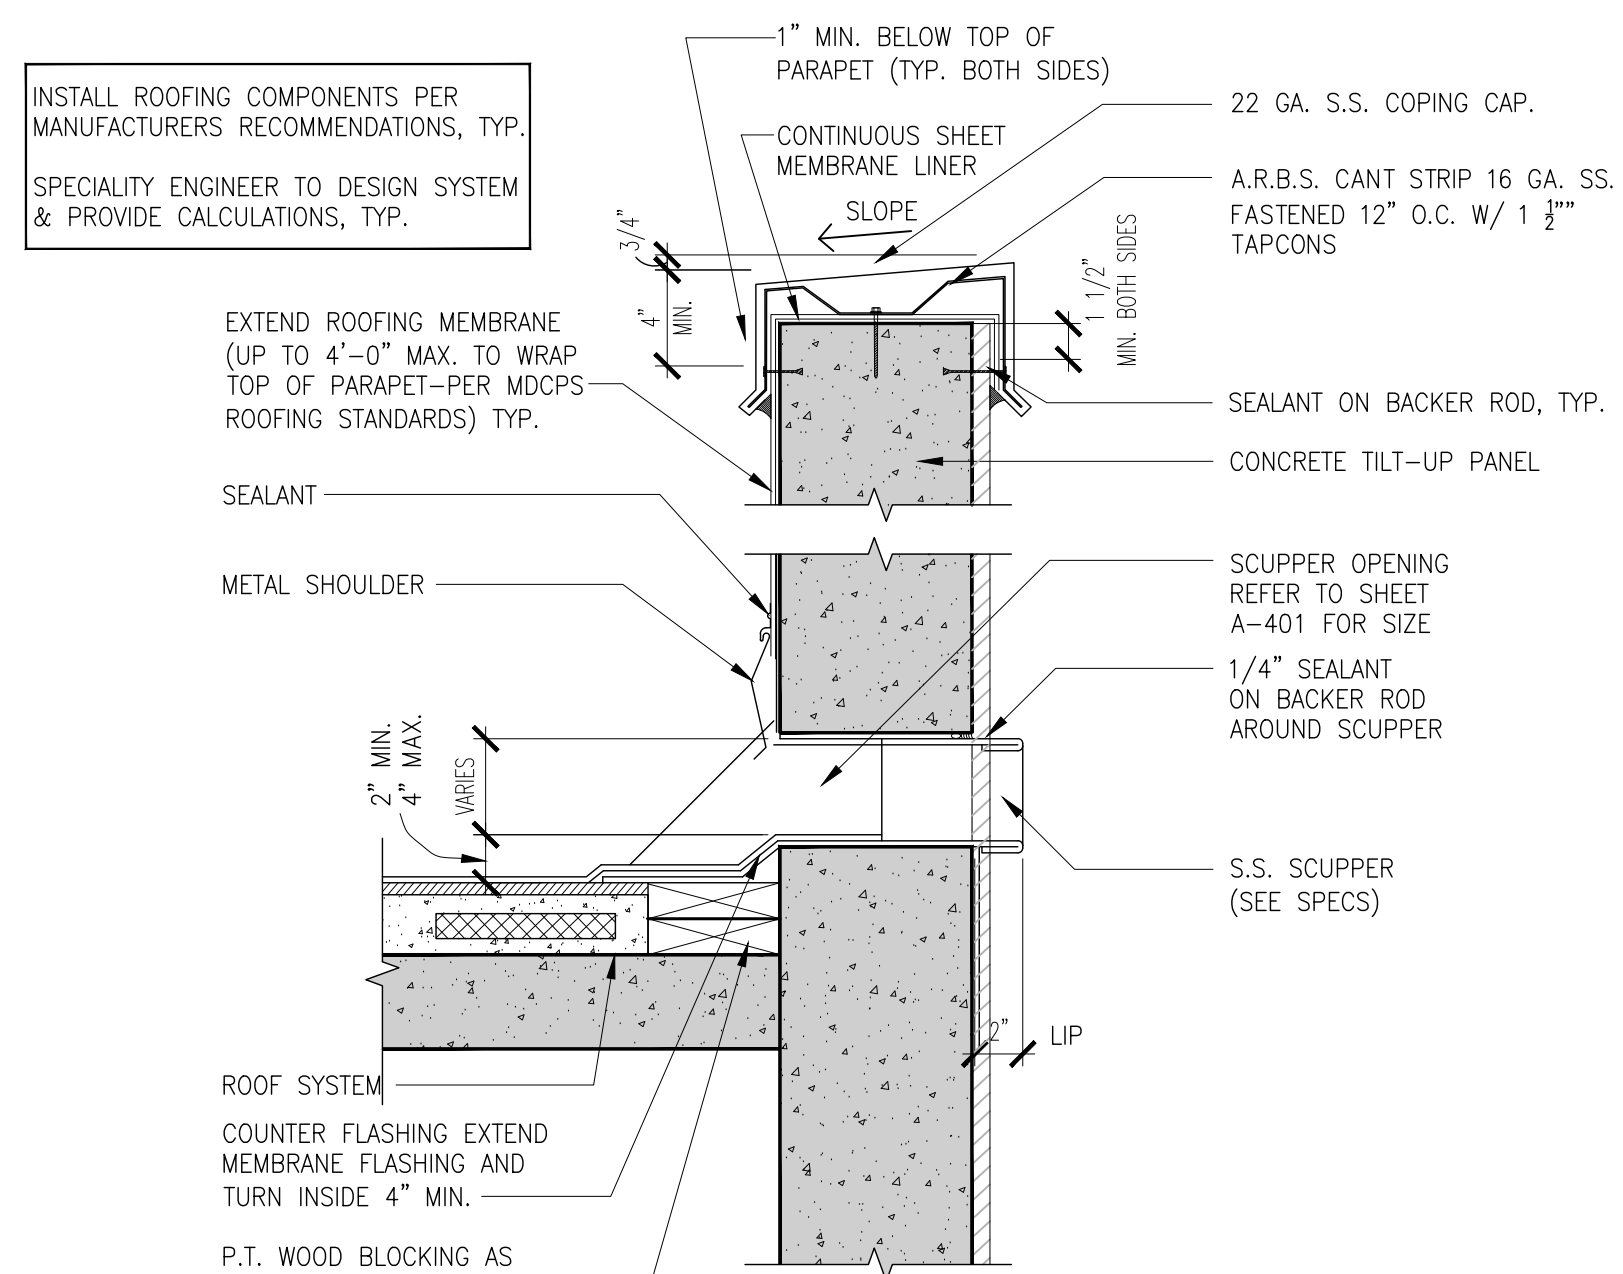


2 EMERGENCY OVERFLOW SCUPPER DETAIL

A-421 Scale: 1 1/2" = 1'-0"

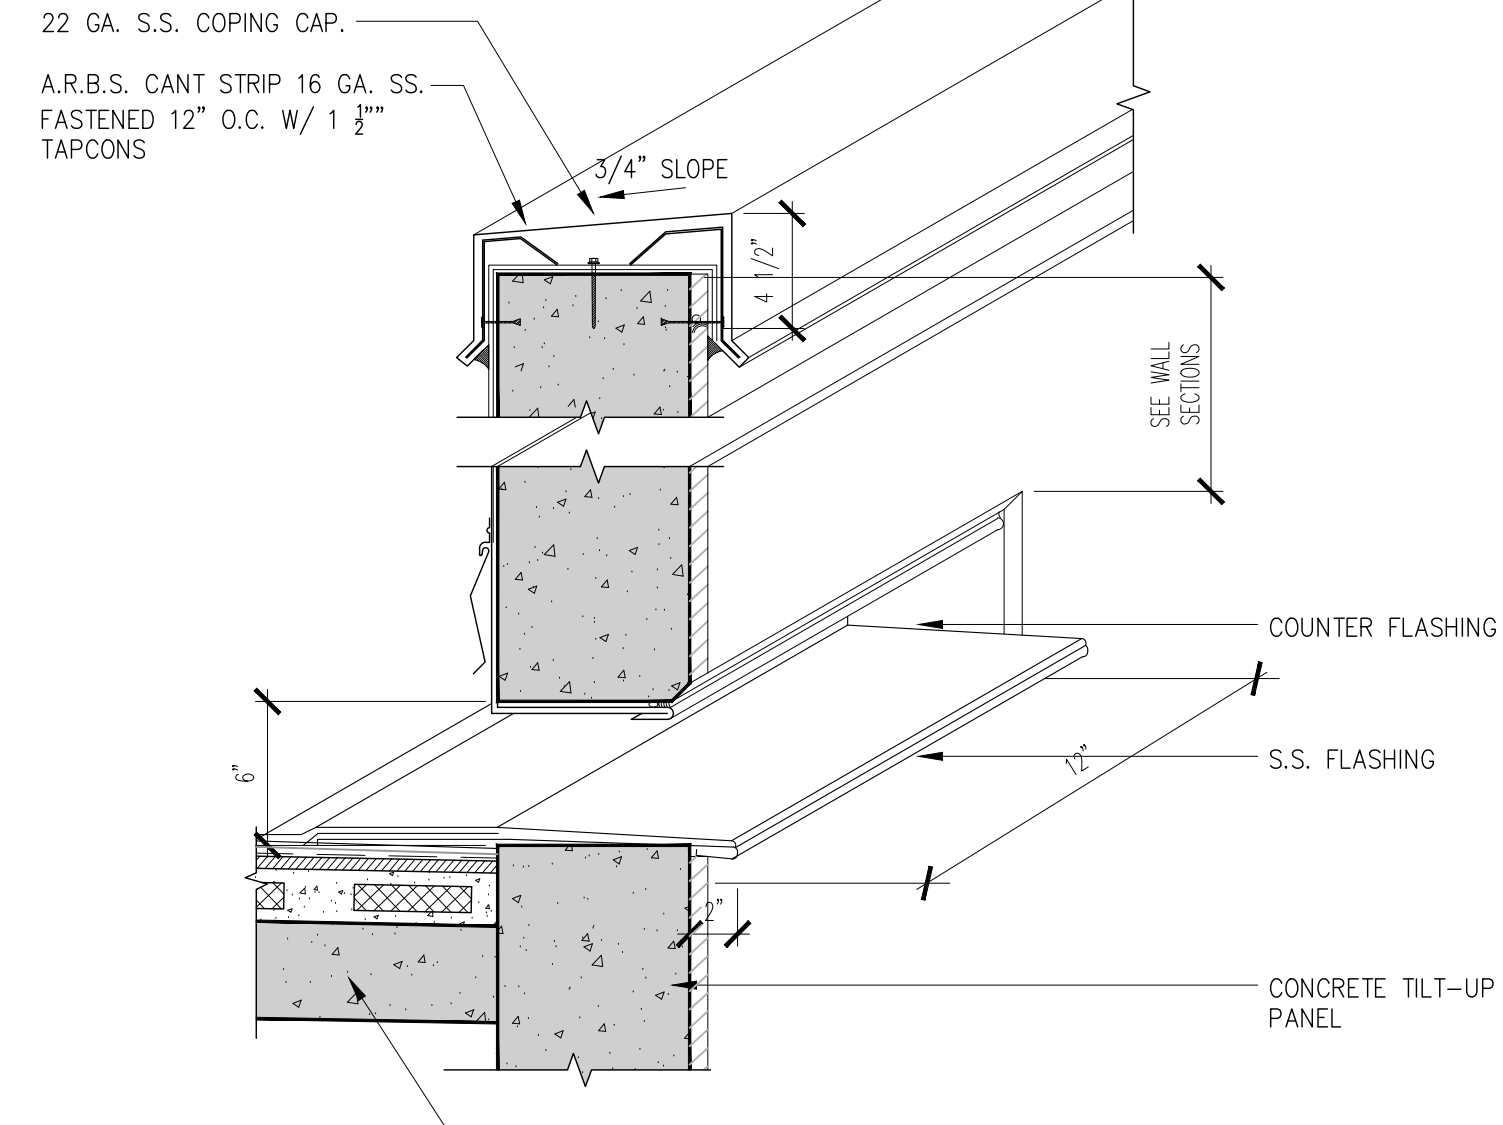


3 TYPICAL SCUPPER OPENING DETAIL

A-421 Scale: 1 1/2" = 1'-0"

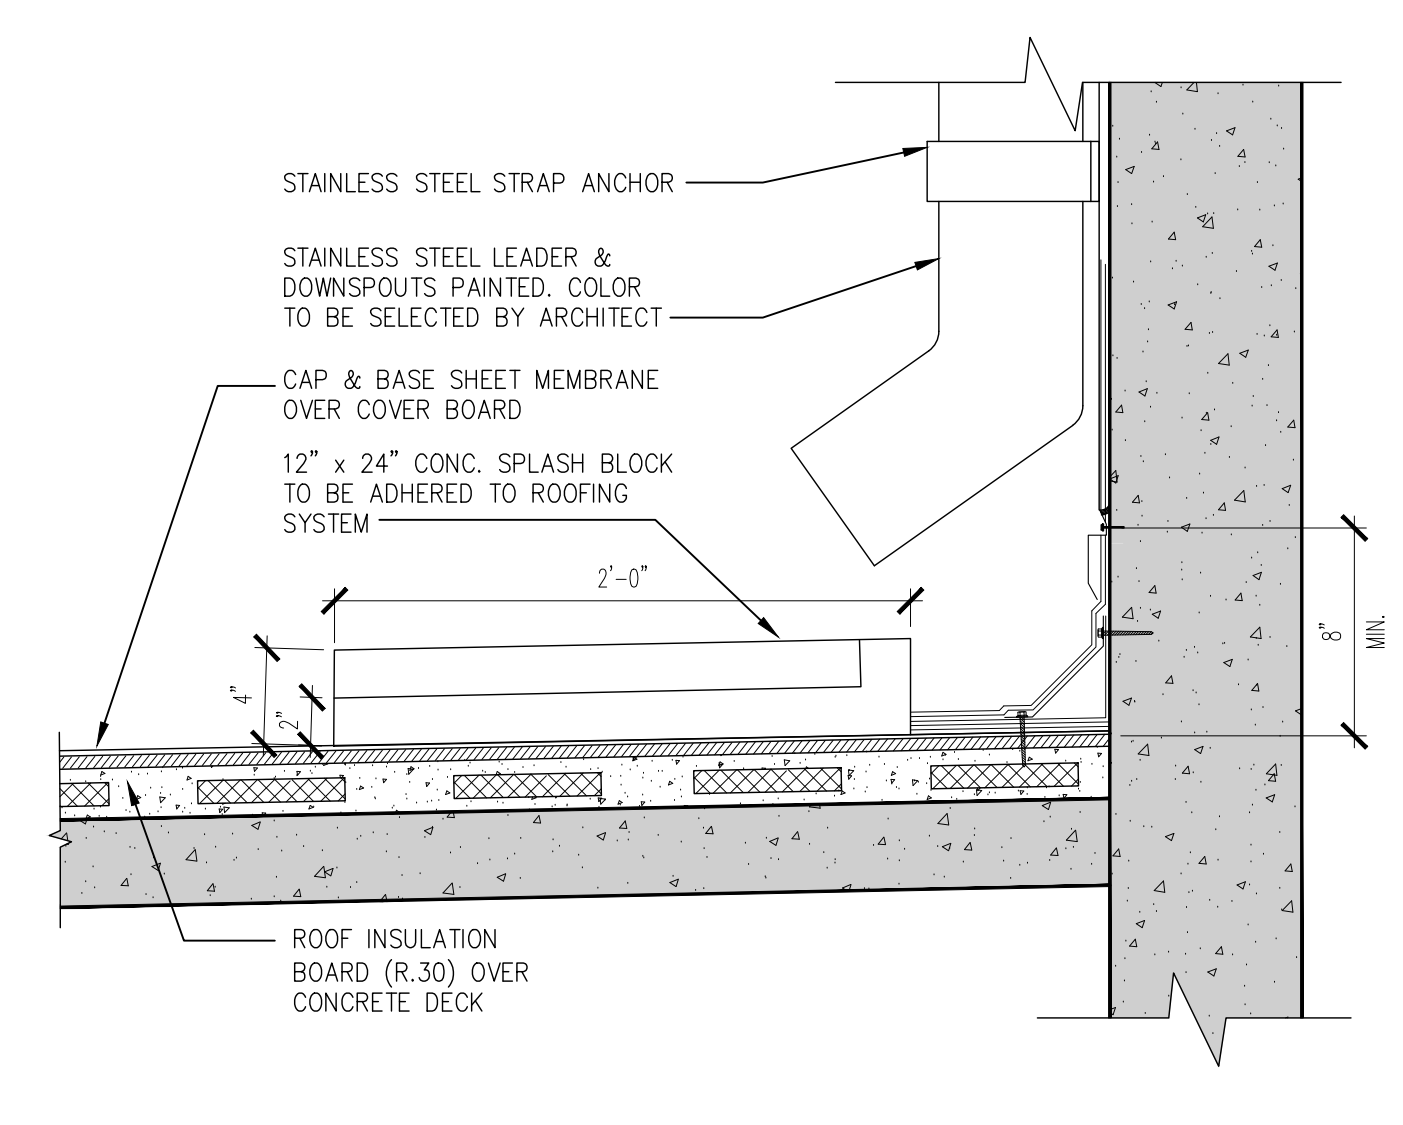


4 SPLASH BLOCK DETAIL

A-421 Scale: 1 1/2" = 1'-0"

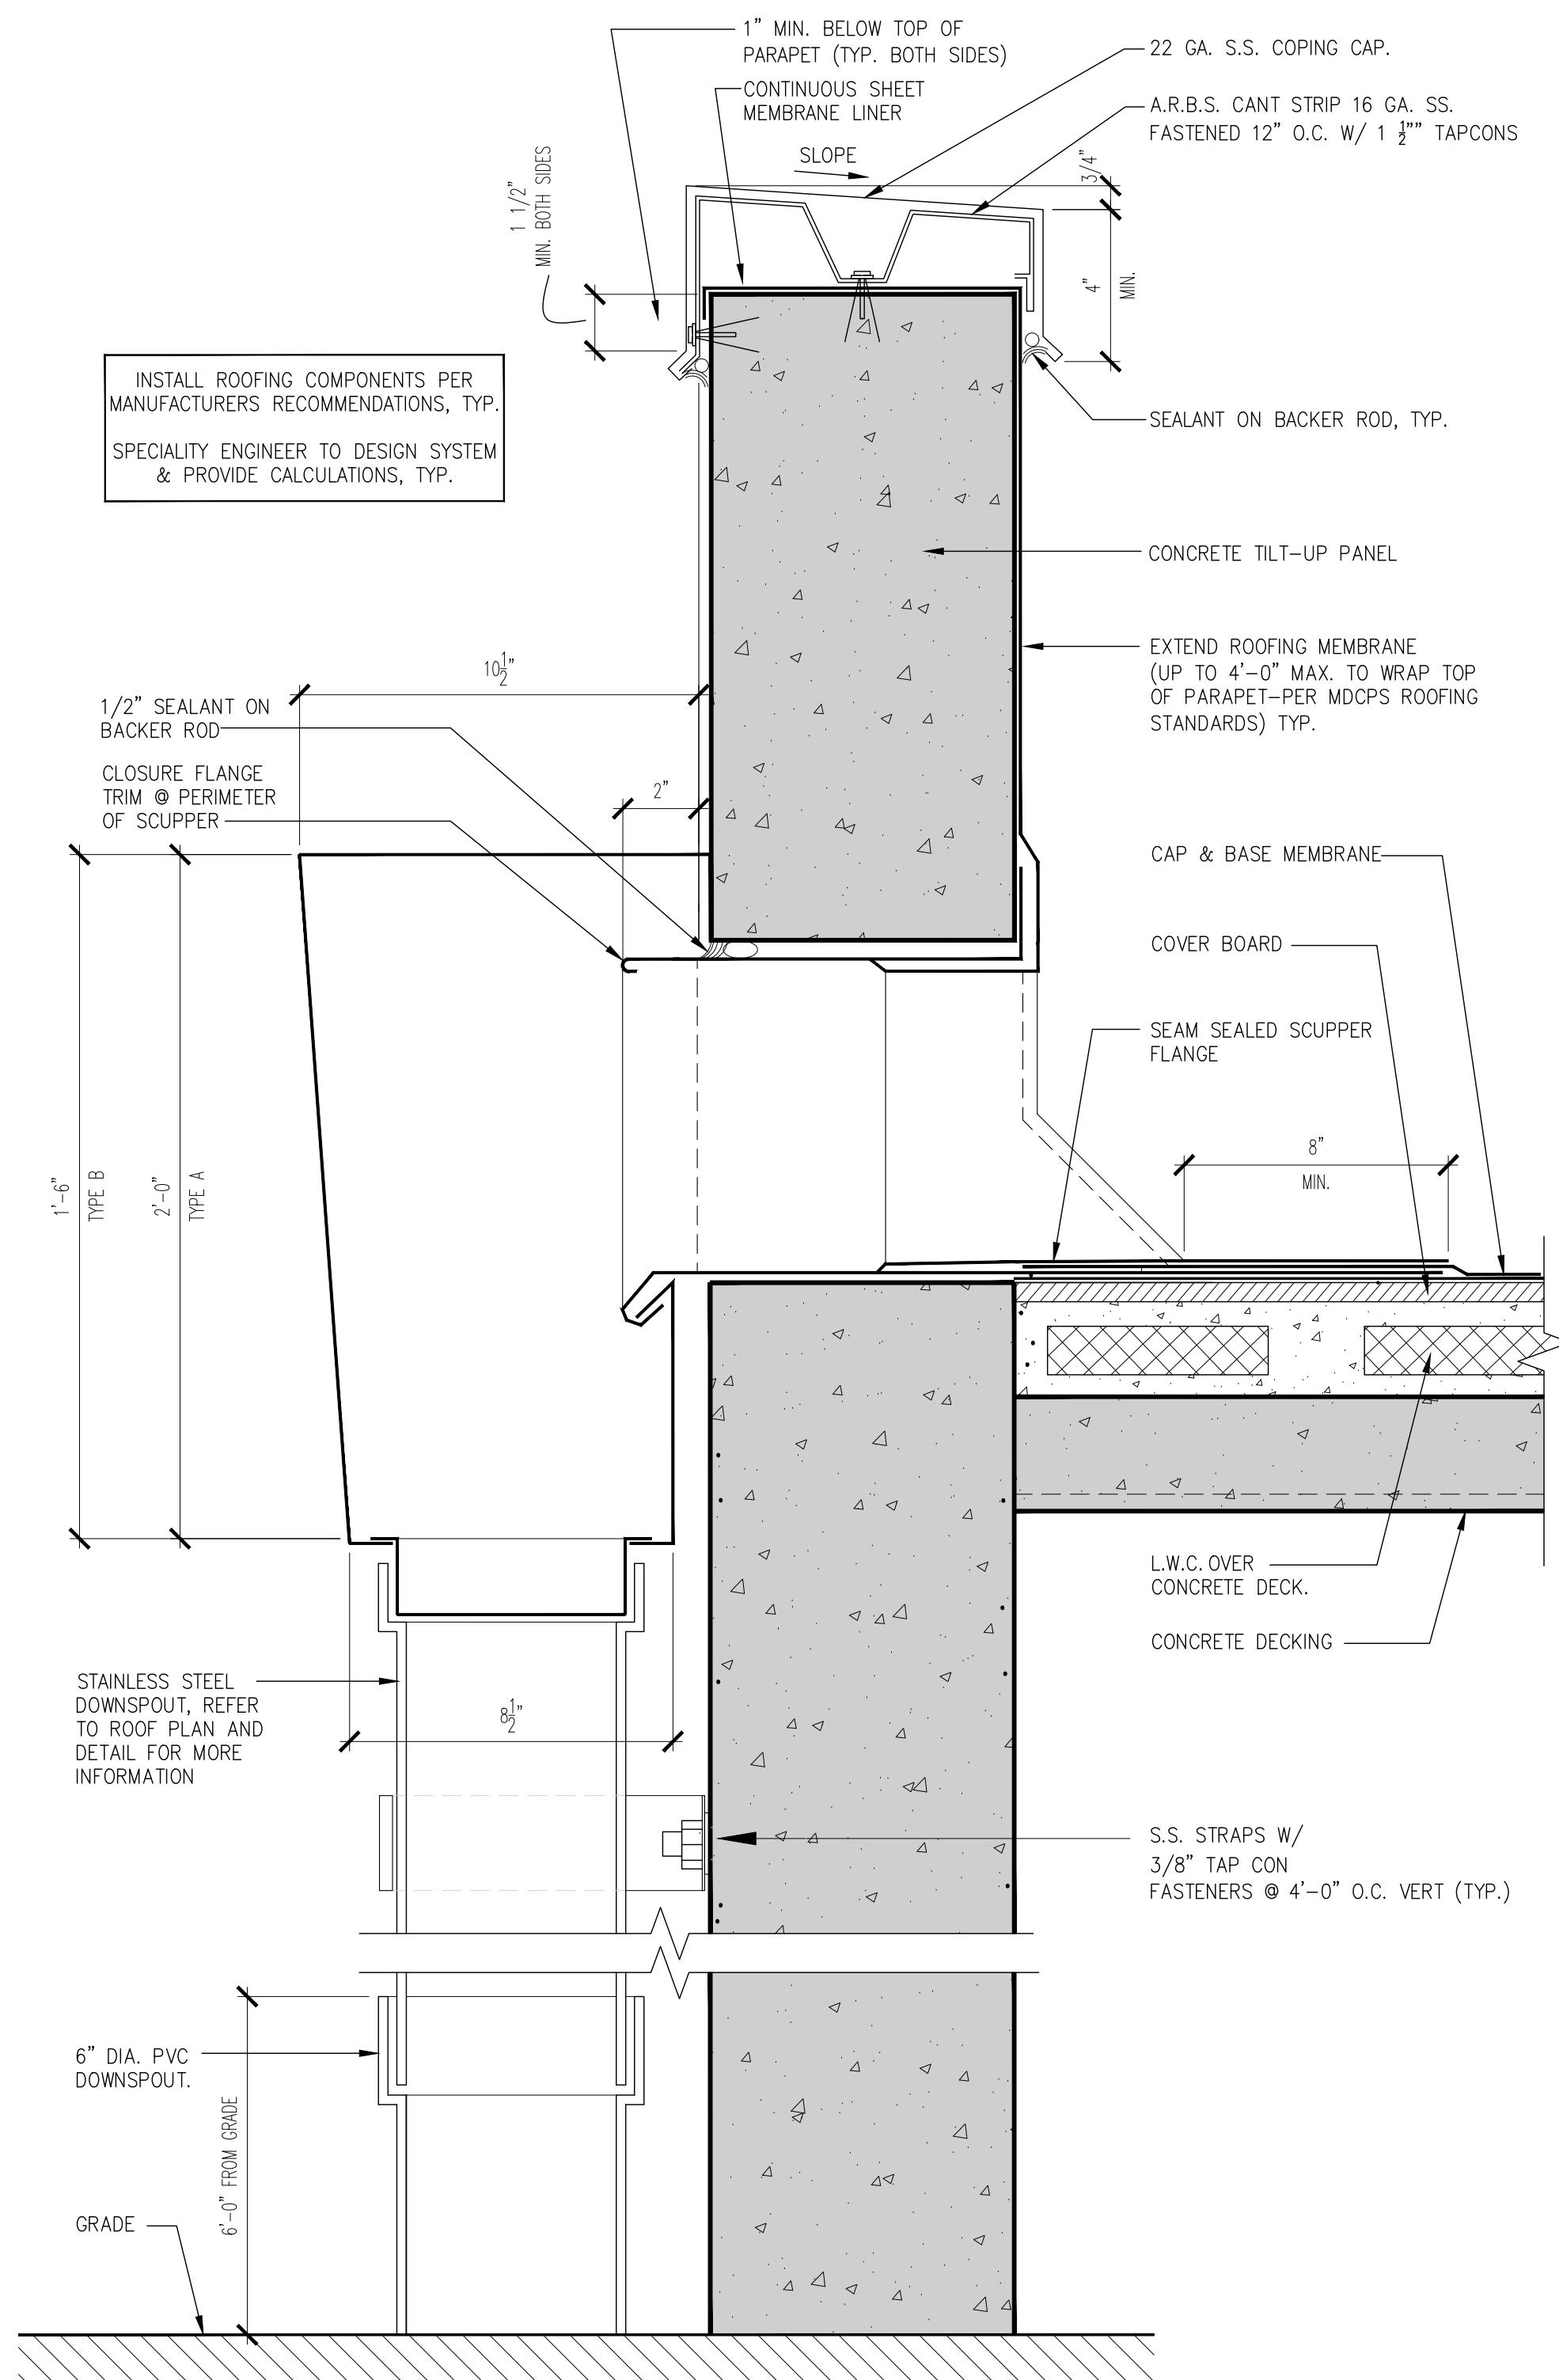


5 SECTION AT COLLECTOR HEAD AND DOWNSPOUT

A-421 Scale: 3" = 1'-0"

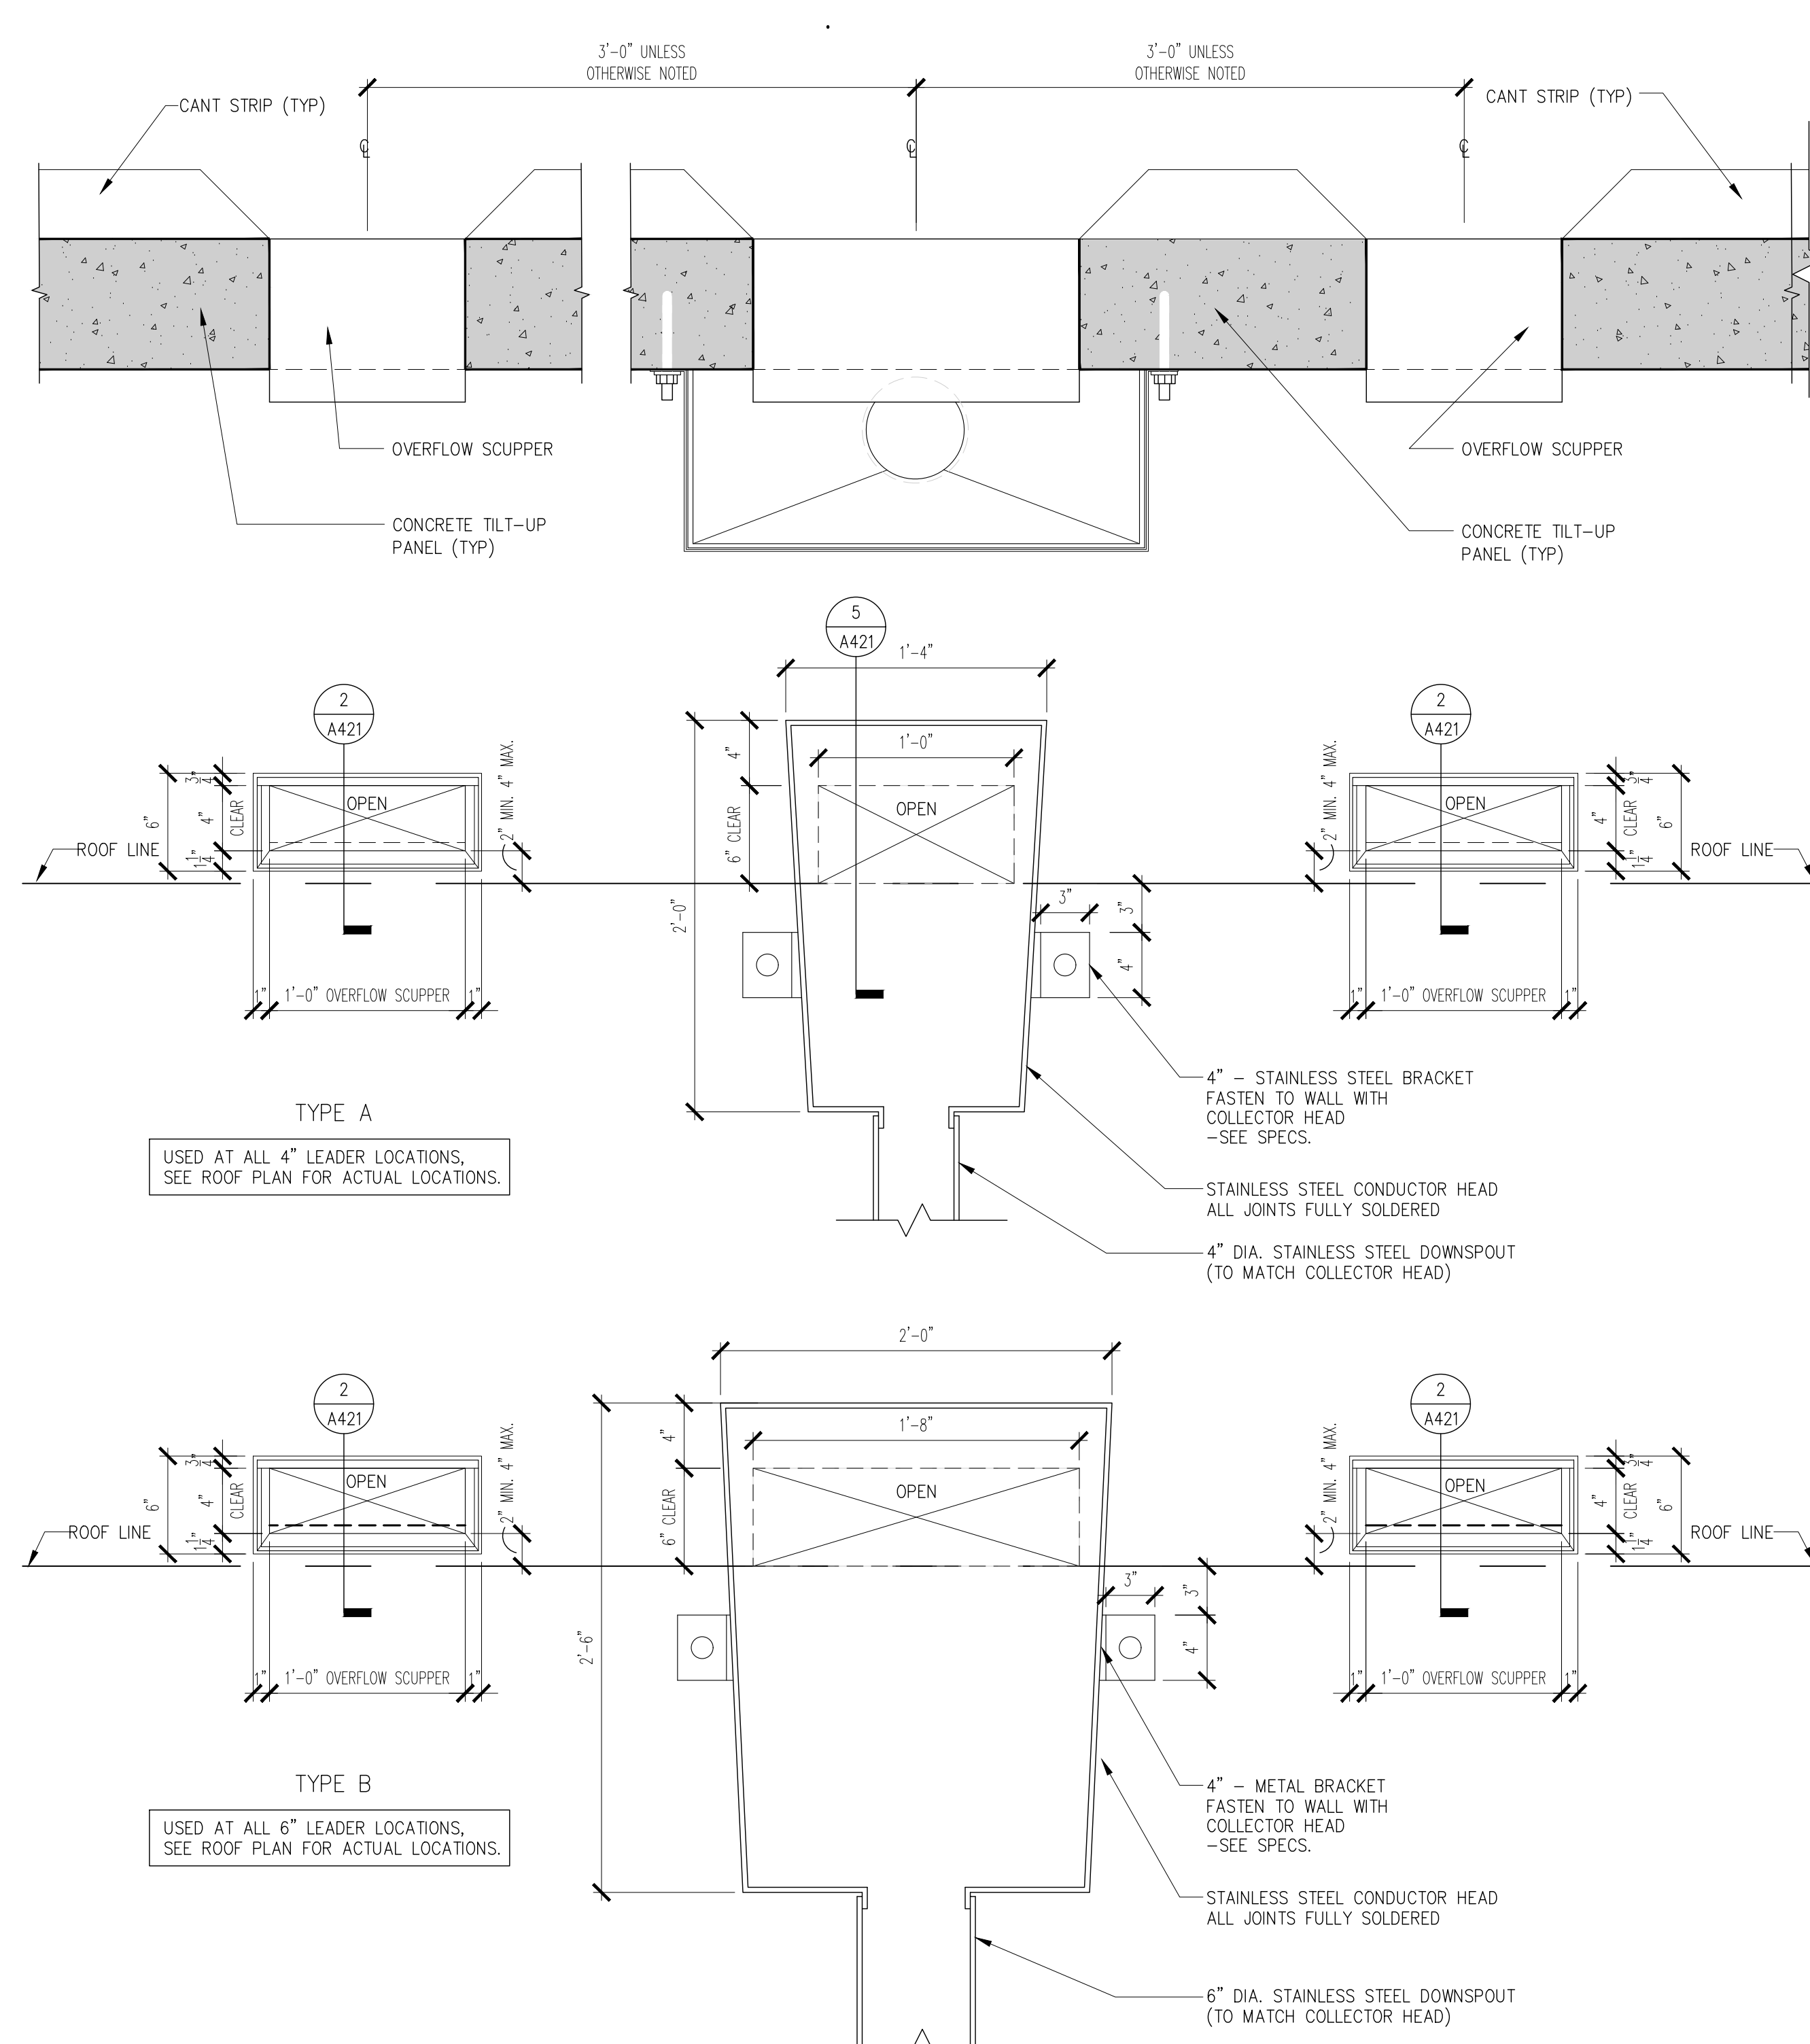

6 DOWNSPOUT AND SCUPPER ELEVATION

A-421 Scale: 1 1/2" = 1'-0"

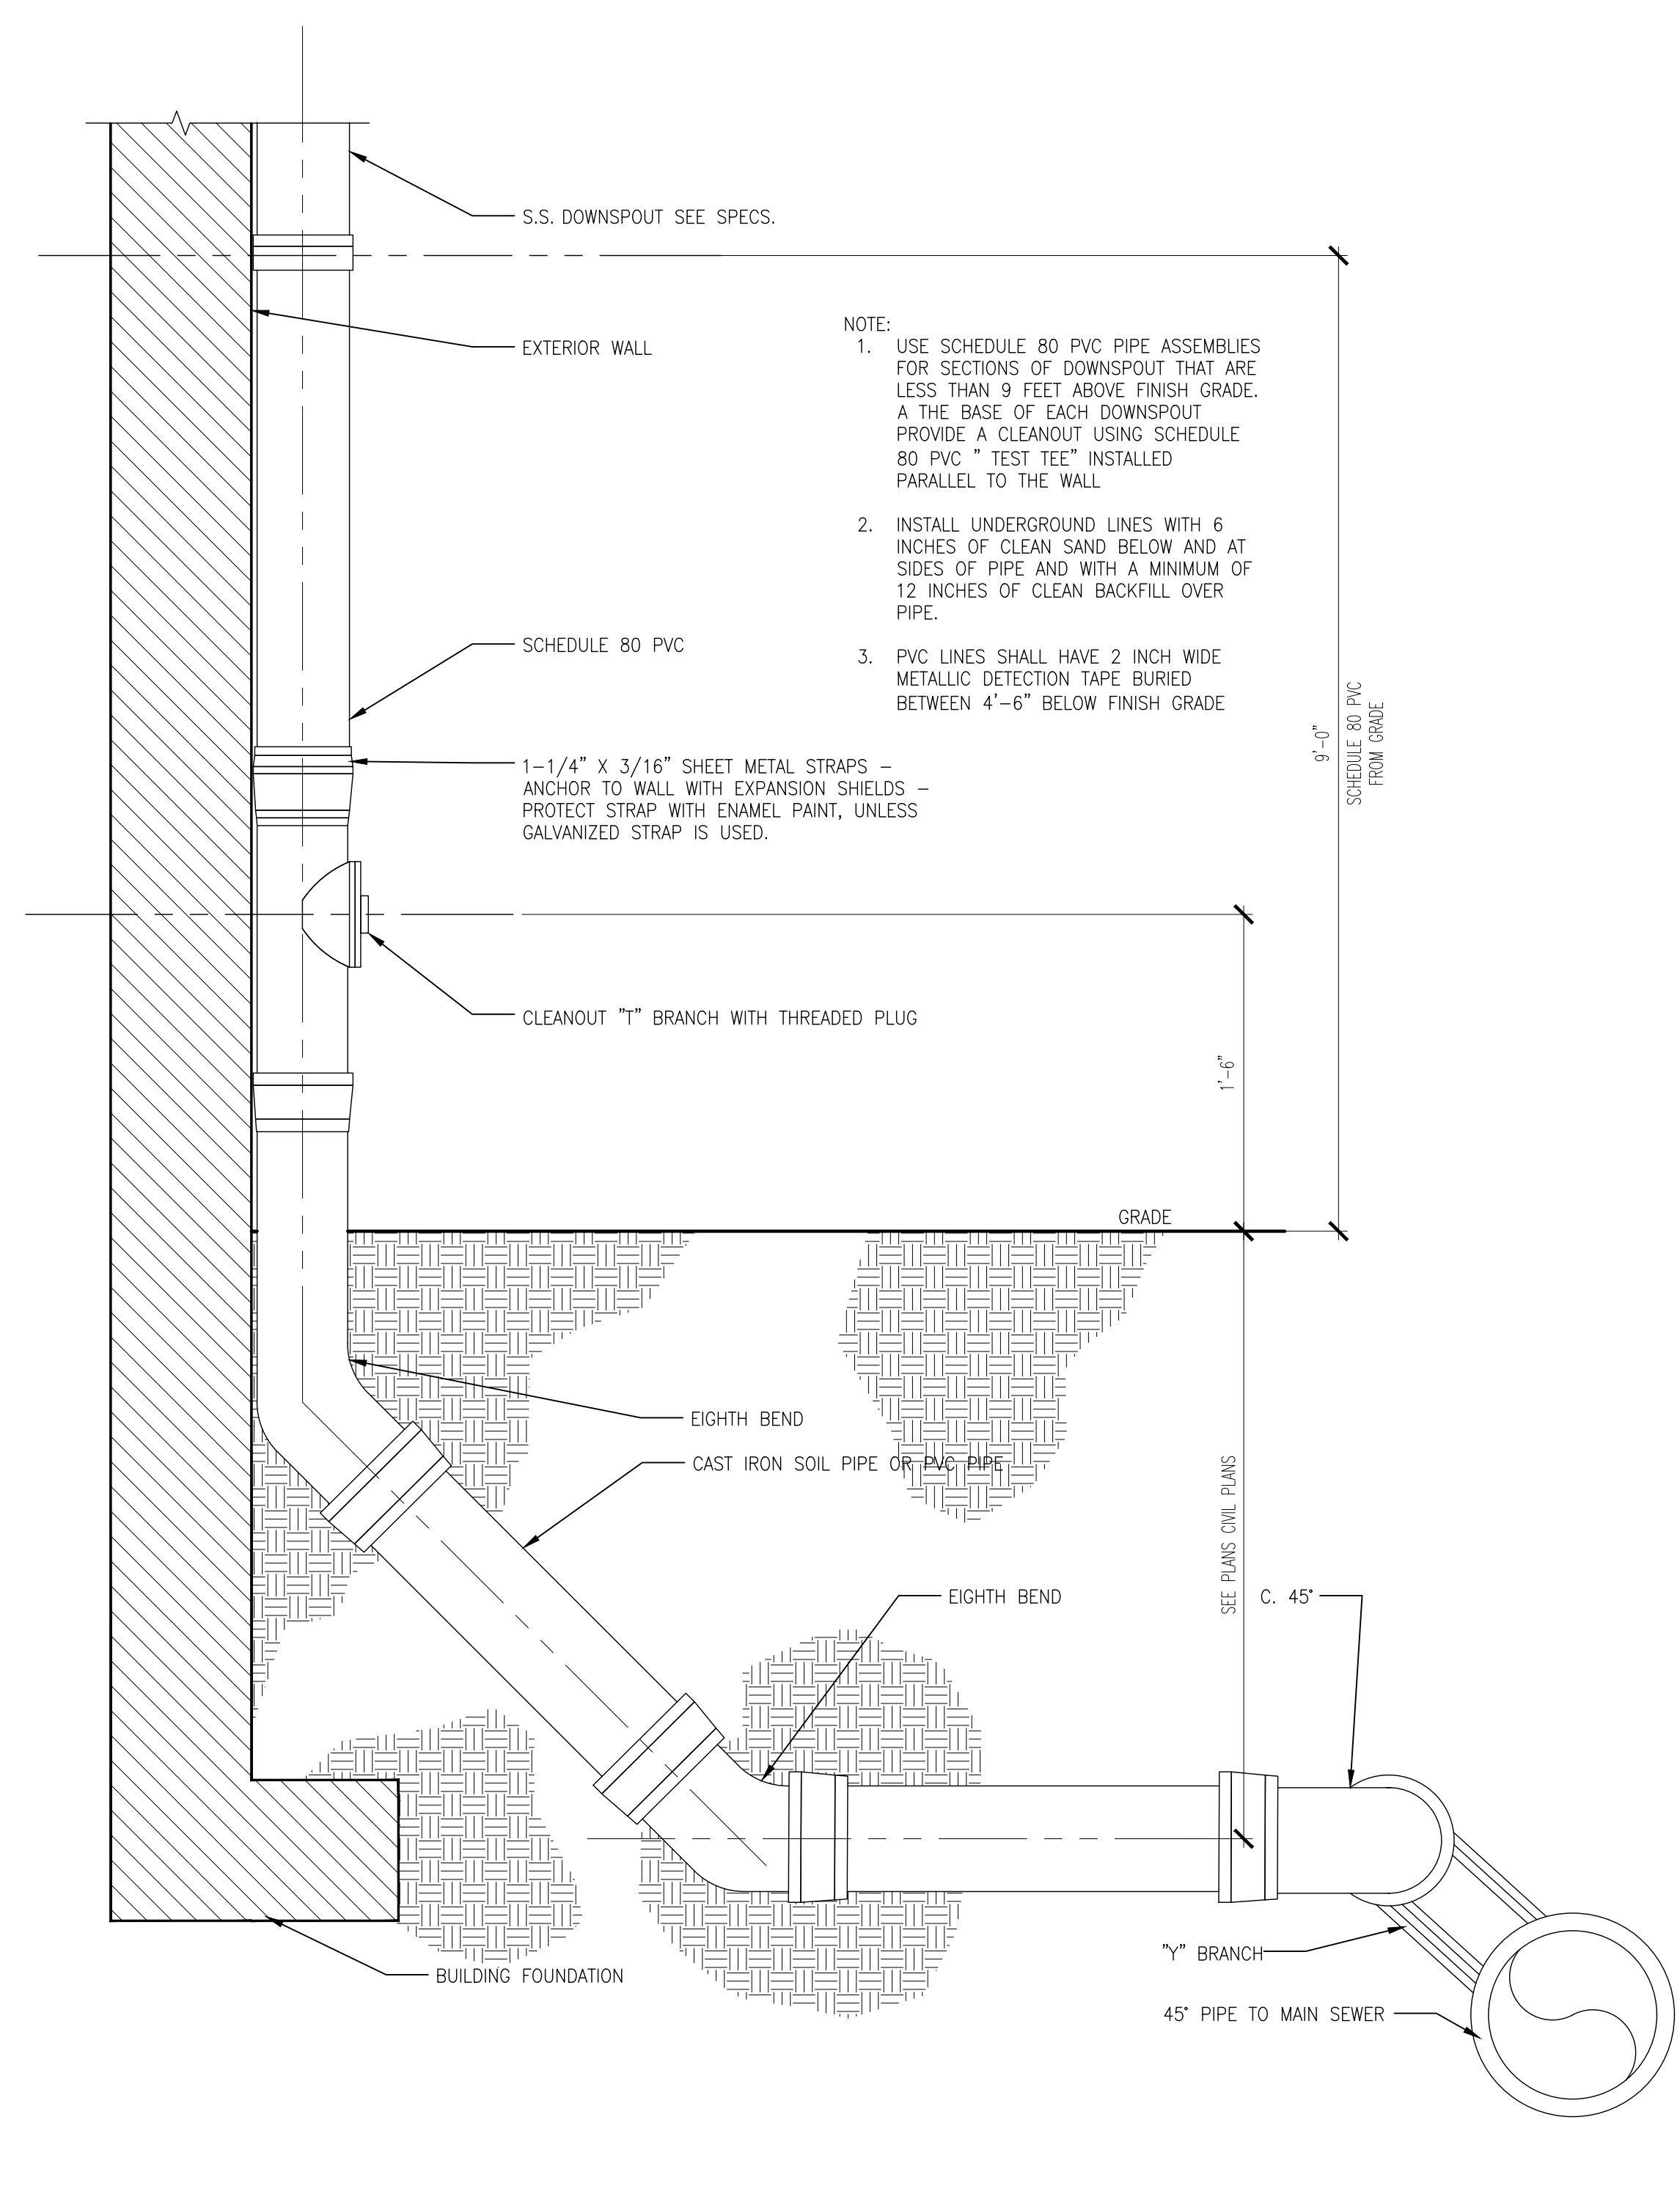


7 DOWNSPOUT SHOE DETAIL

A-421 Scale: 1 1/2" = 1'-0"


CHECKED BY: LR. DRAWN BY: CV.

CONSULTANT INFO:

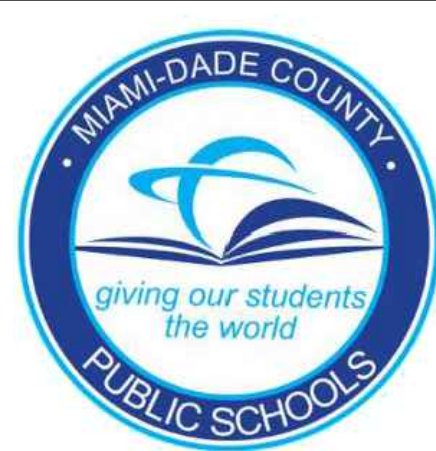


NEW ELEMENTARY SCHOOL (K-5)
VENETIAN PARC WEST
SOUTHWEST 157th AVENUE and 174th STREET
MIAMI, FL. 33187
MDCPS PROJECT No. 01892600

KEY PLAN

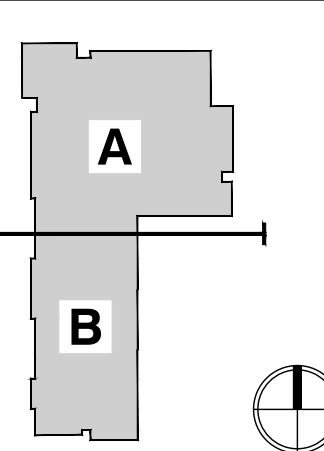

CONSULTANT INFO:
















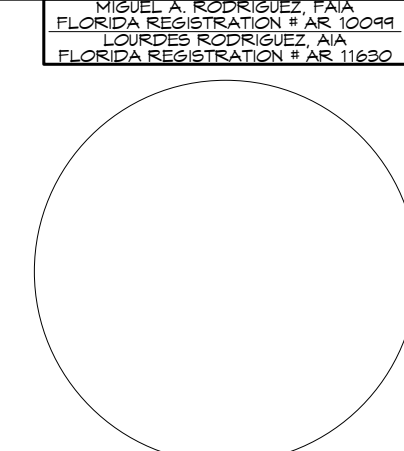



RODRIGUEZ ARCHITECTS INCORPORATED
2121 PONCE DE LEON BLVD. STE 1010
CORAL GABLES, FL. 33134
TEL: (305) 448-3373
FAX: (305) 448-3374
A A C - 0 0 1 9 3 3

RAI


REVISIONS:

DRAWING TITLE:
ROOF DETAILS
SCALE AS NOTED
ISSUE DATE: 12/16/14 PROJECT NO.:
SHEET: **A-421**

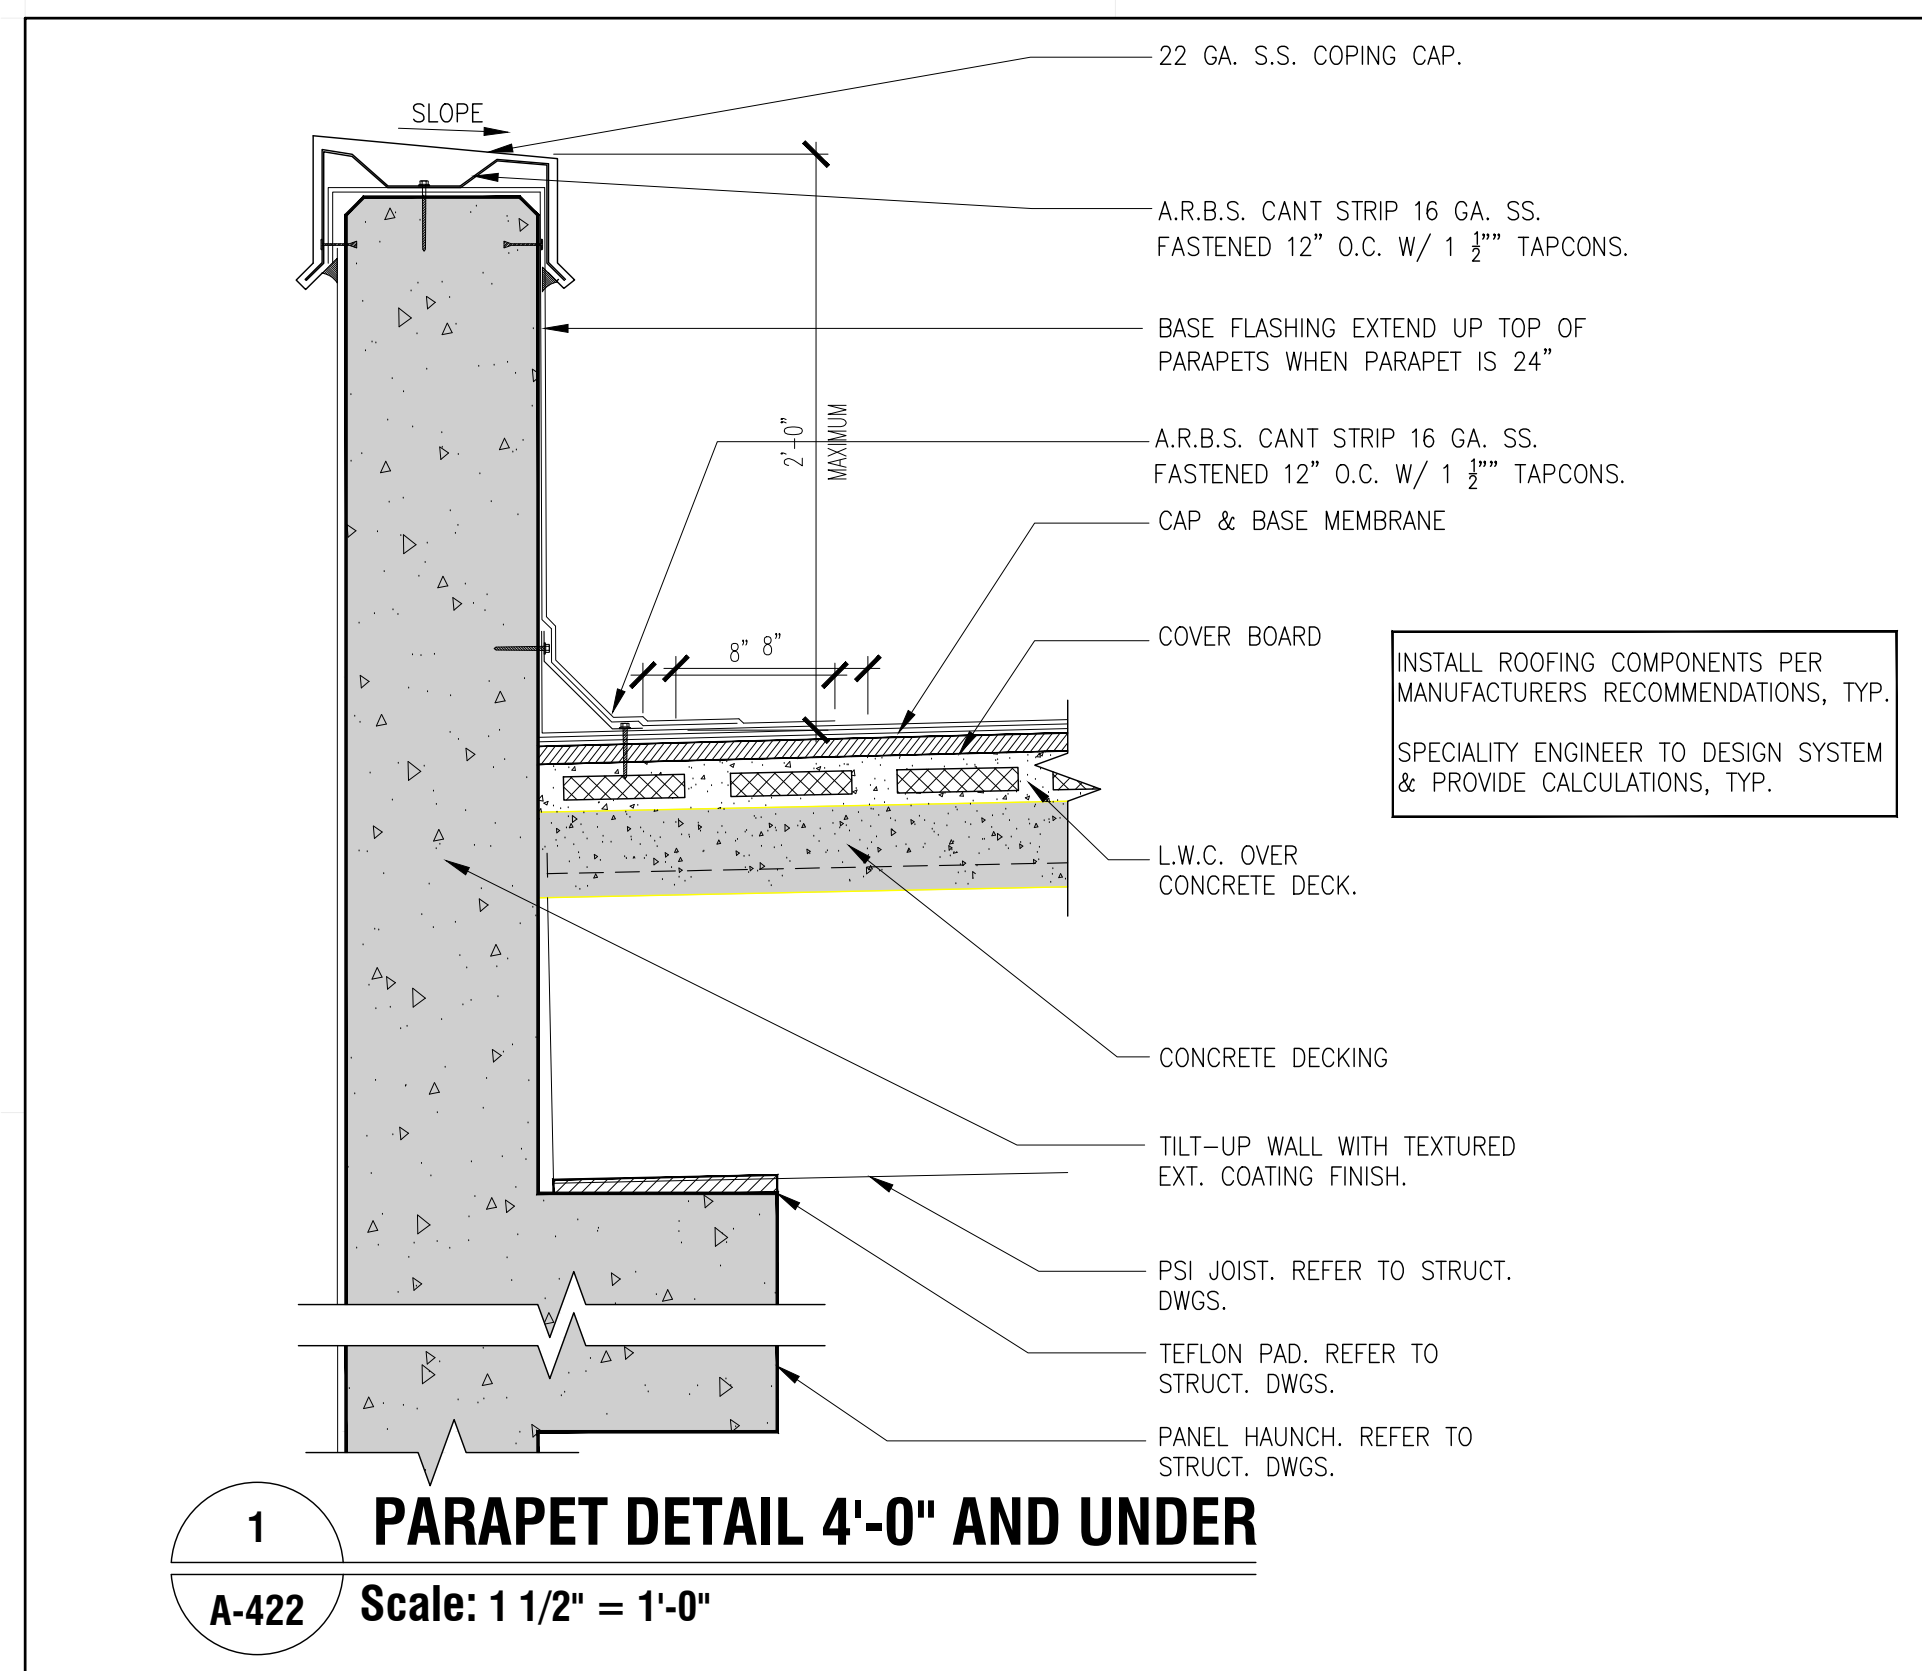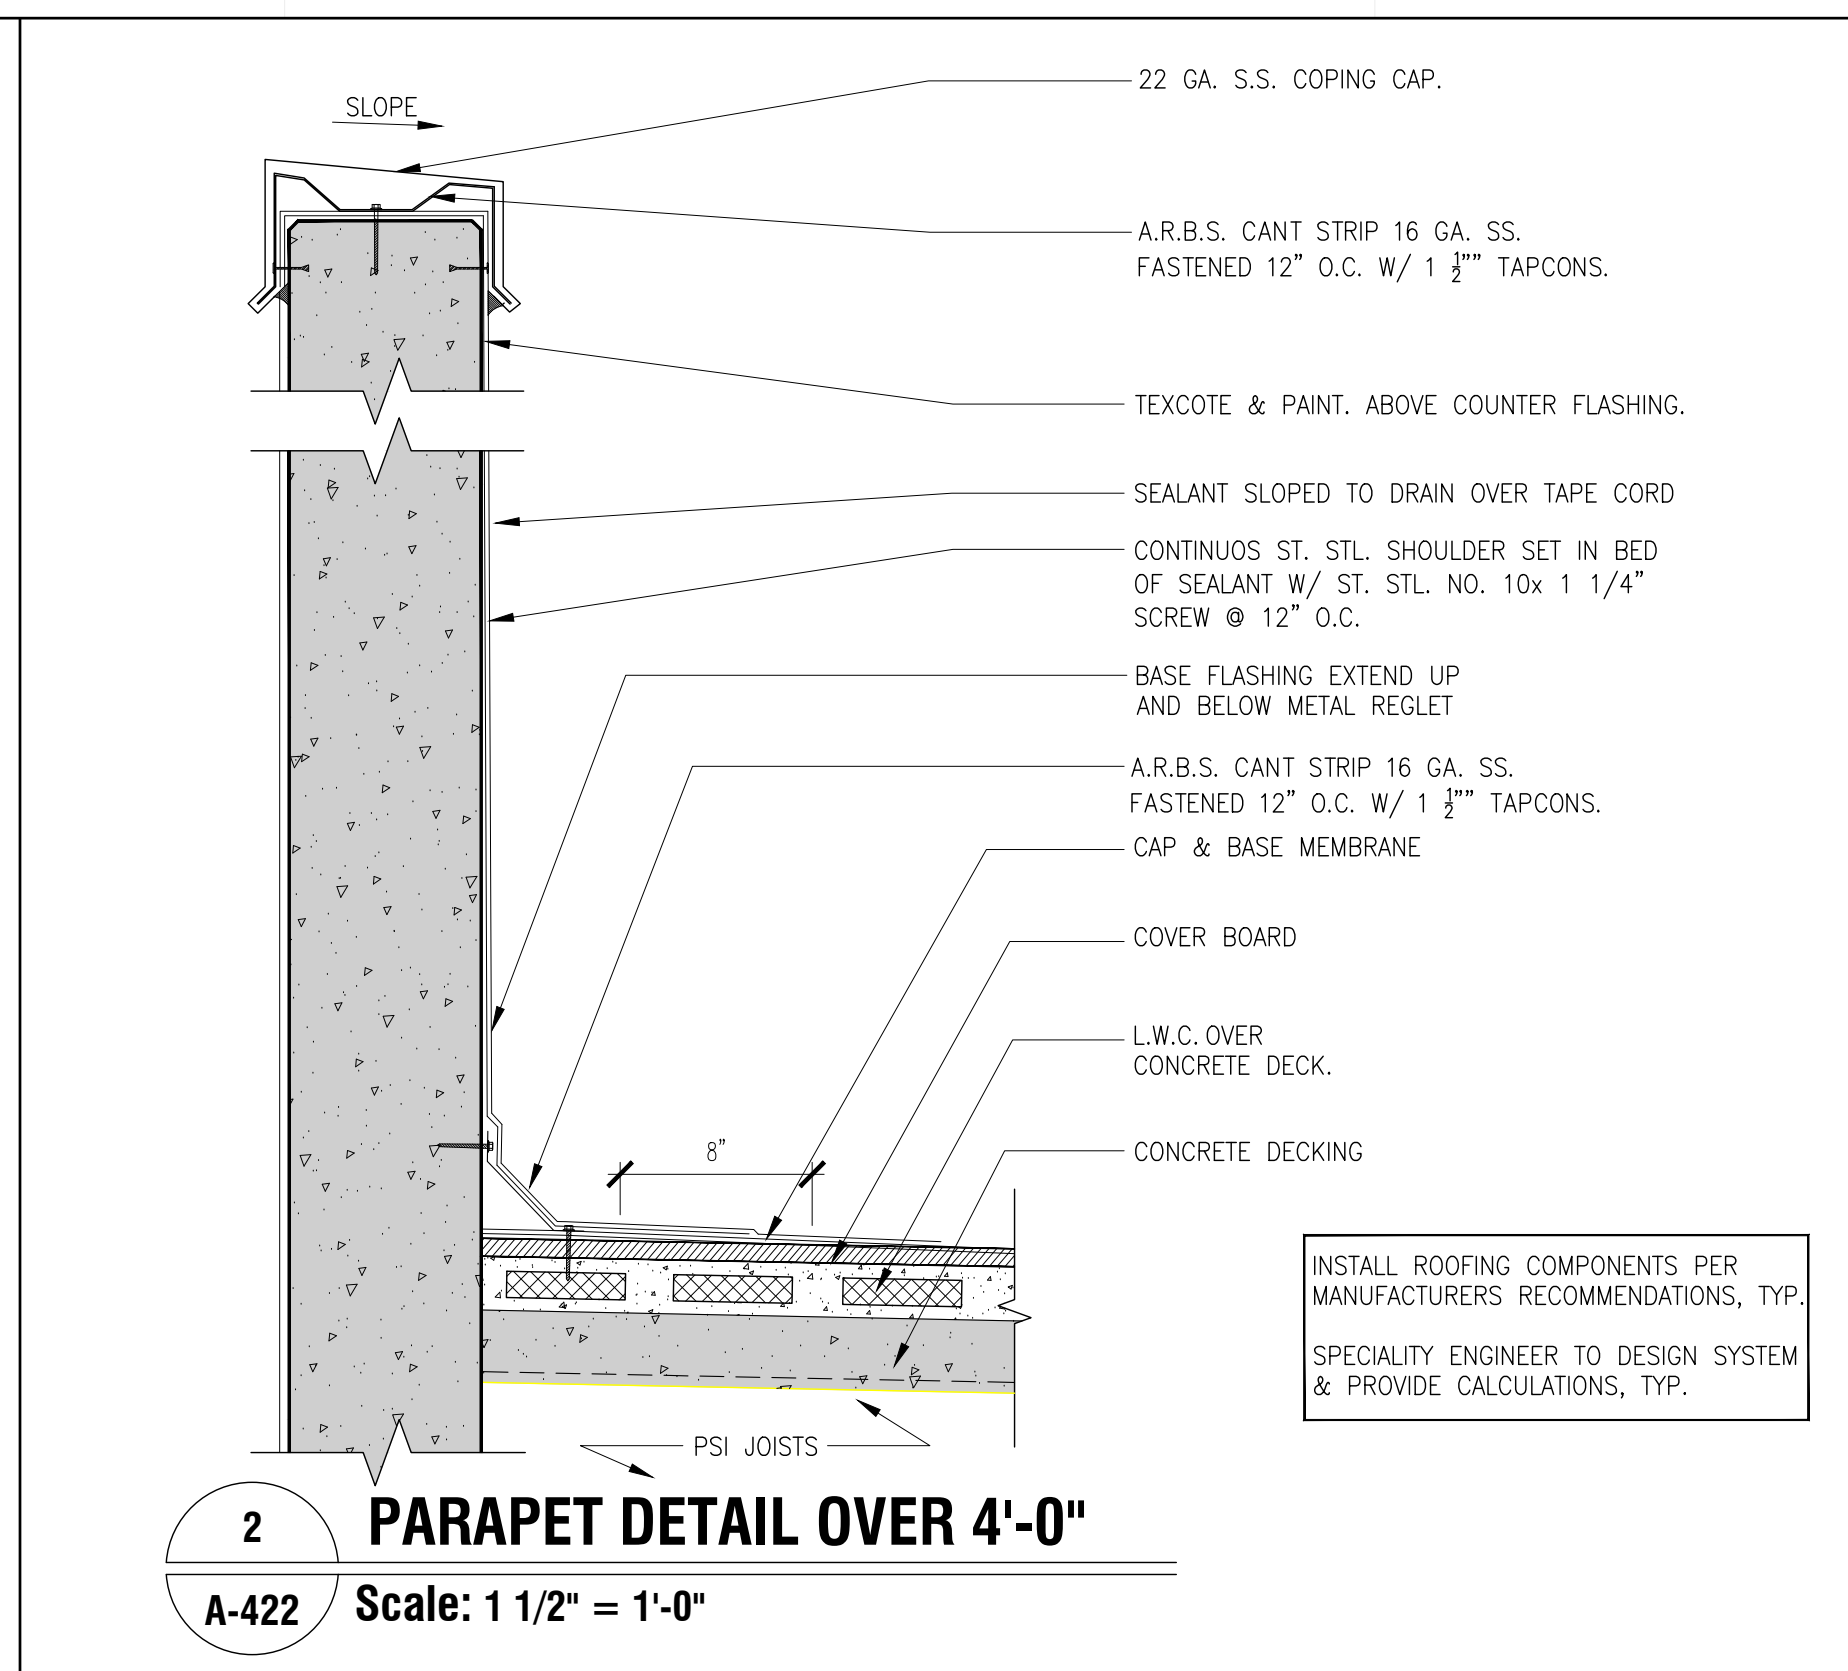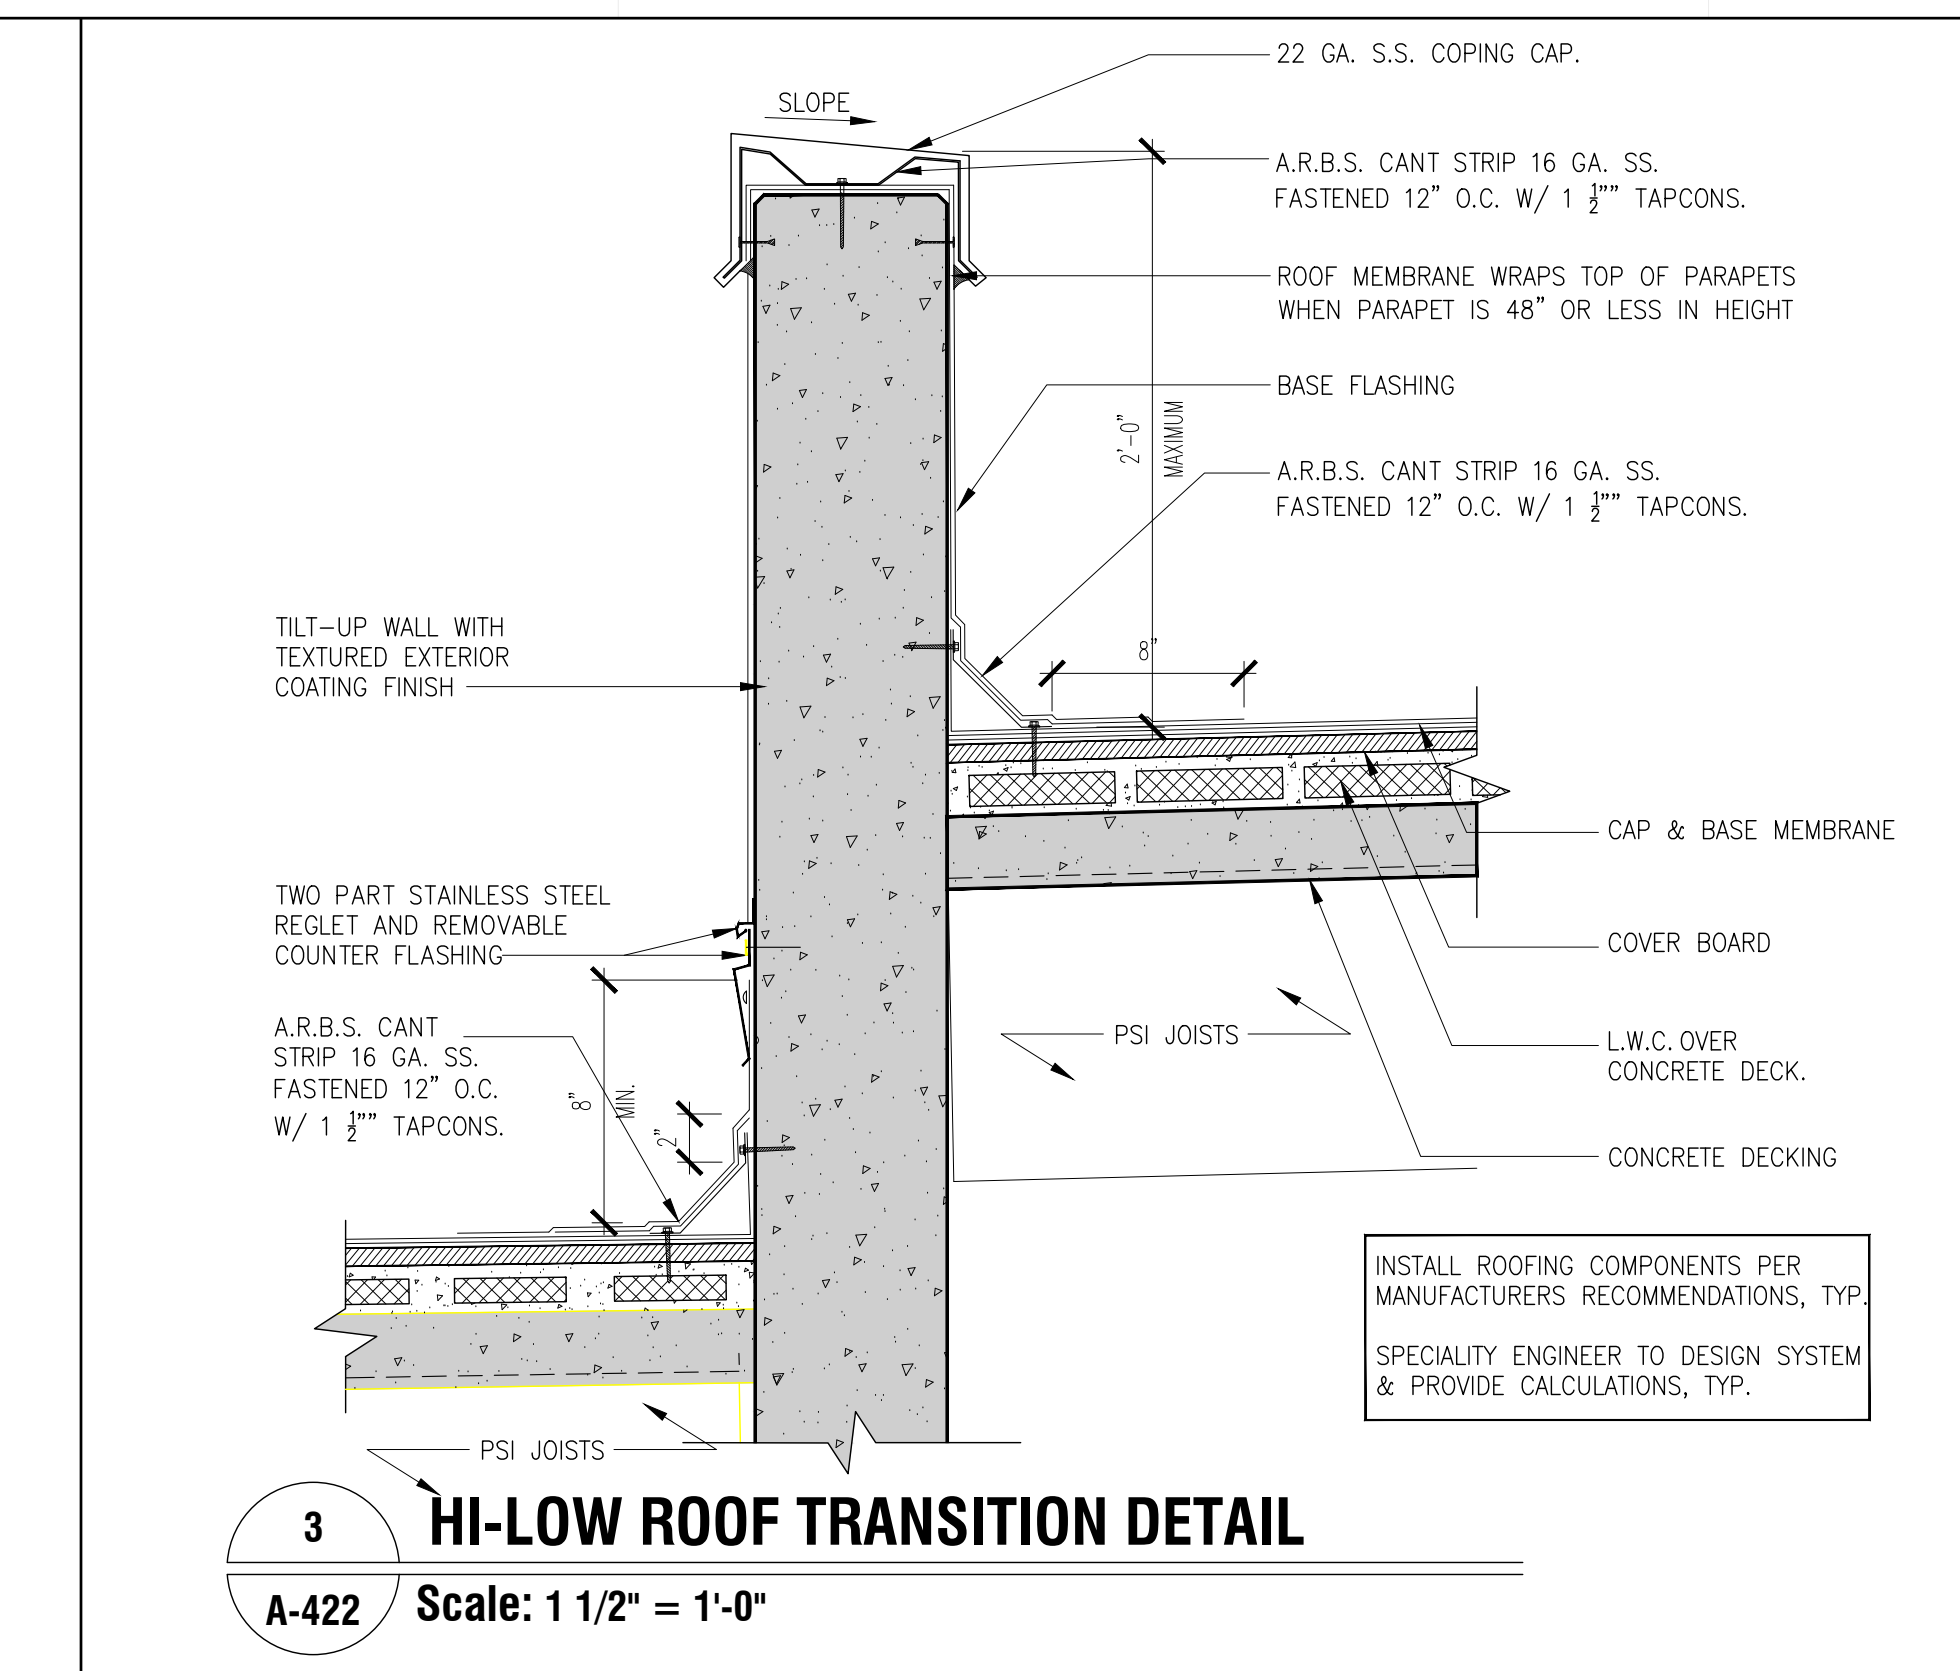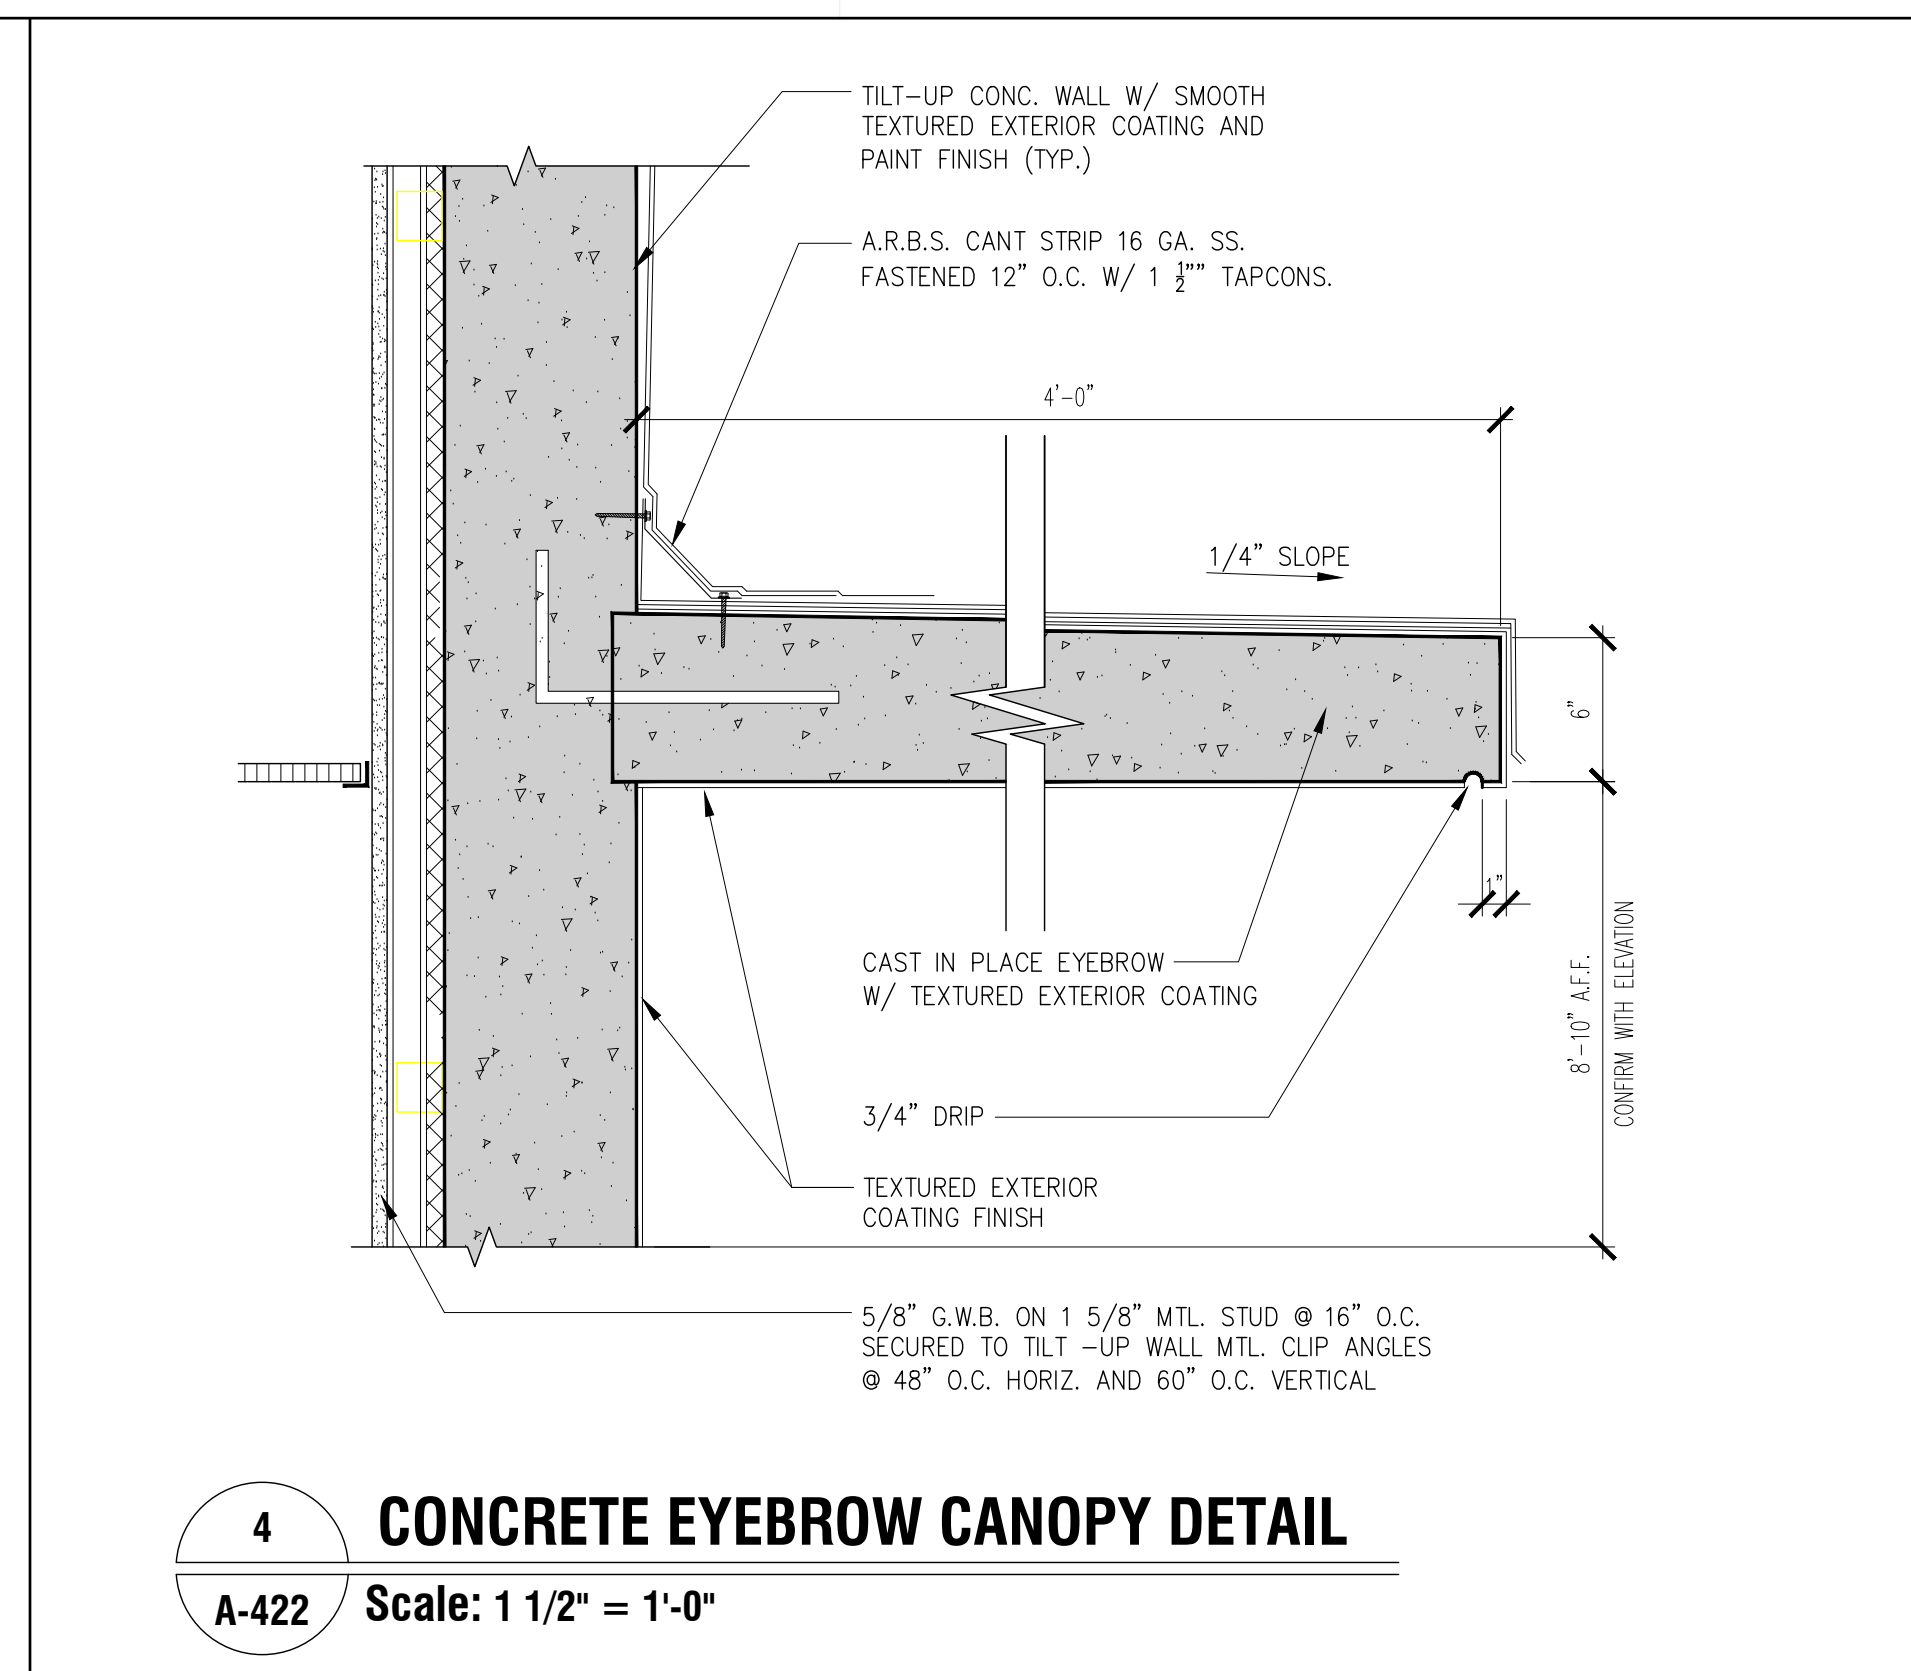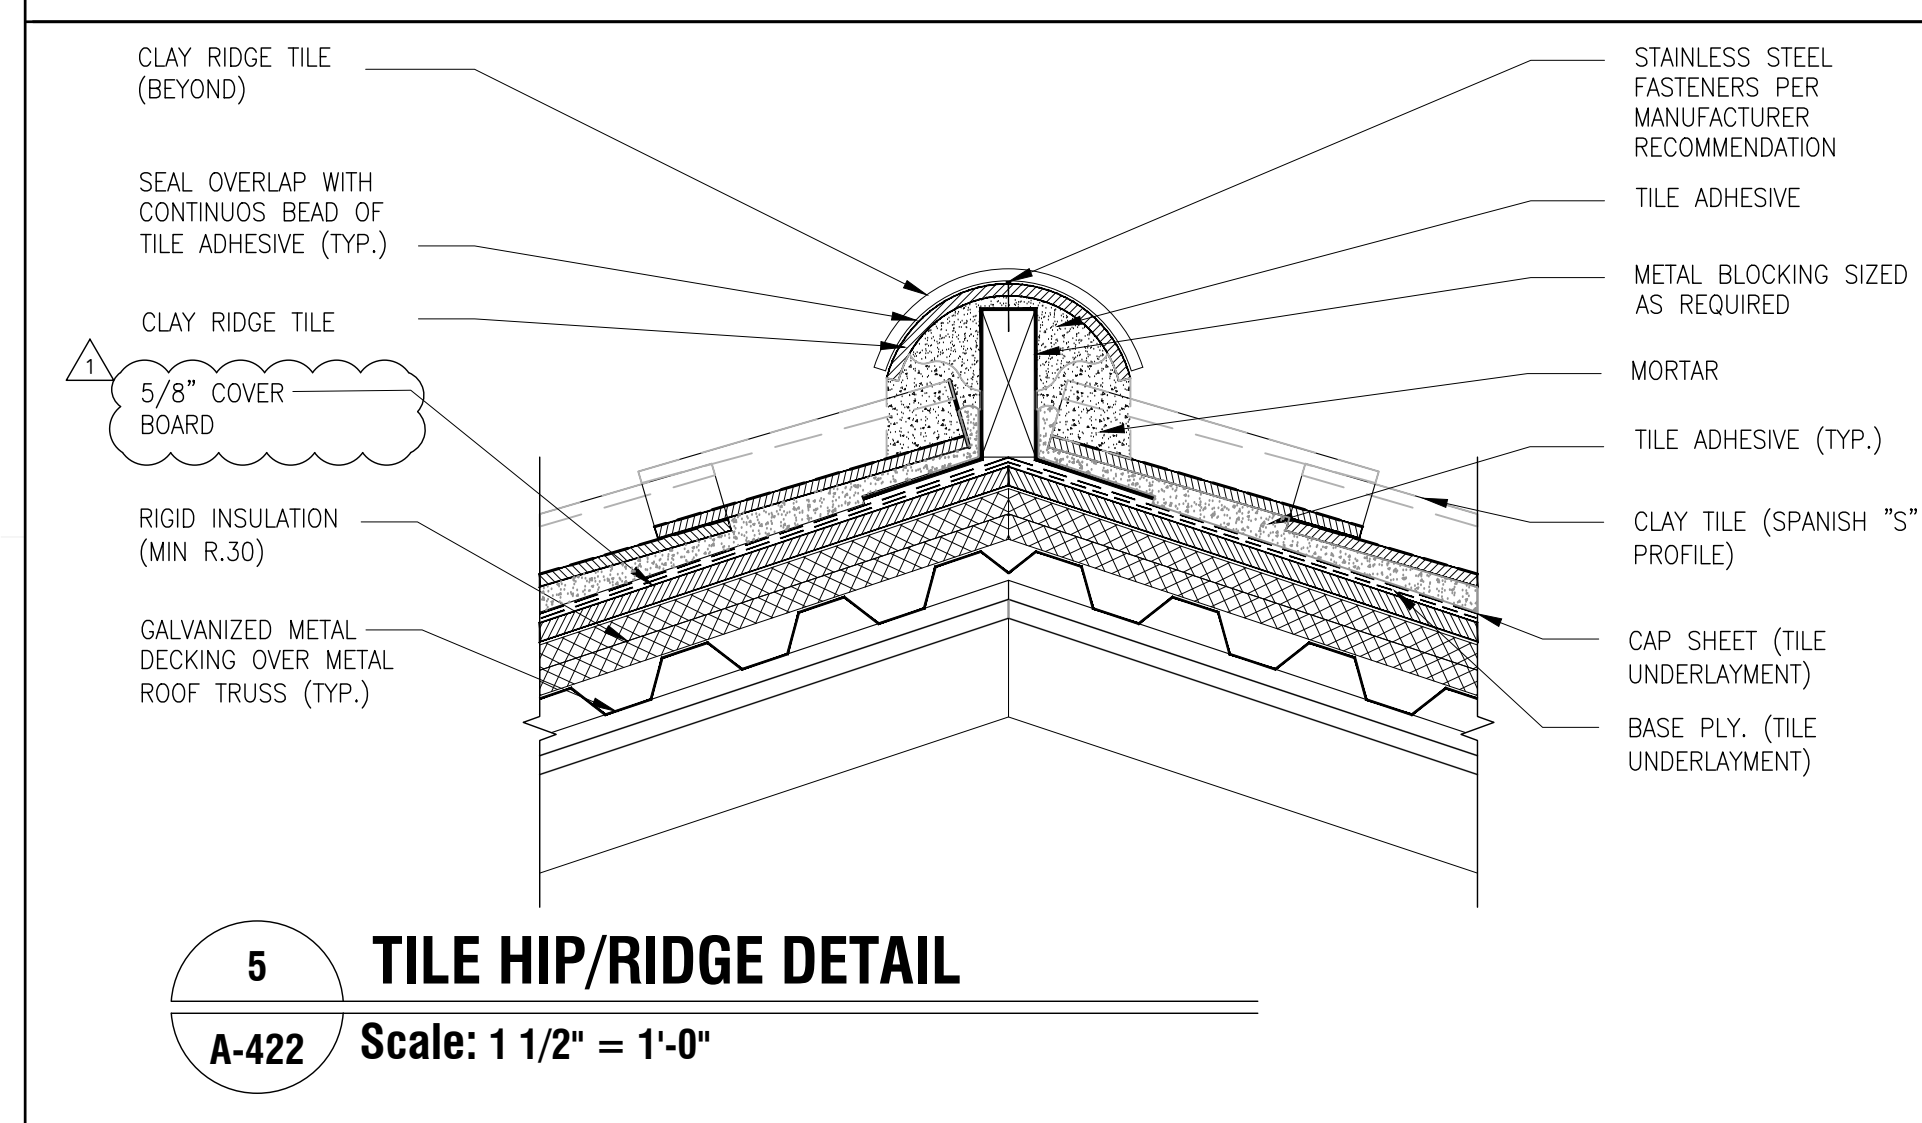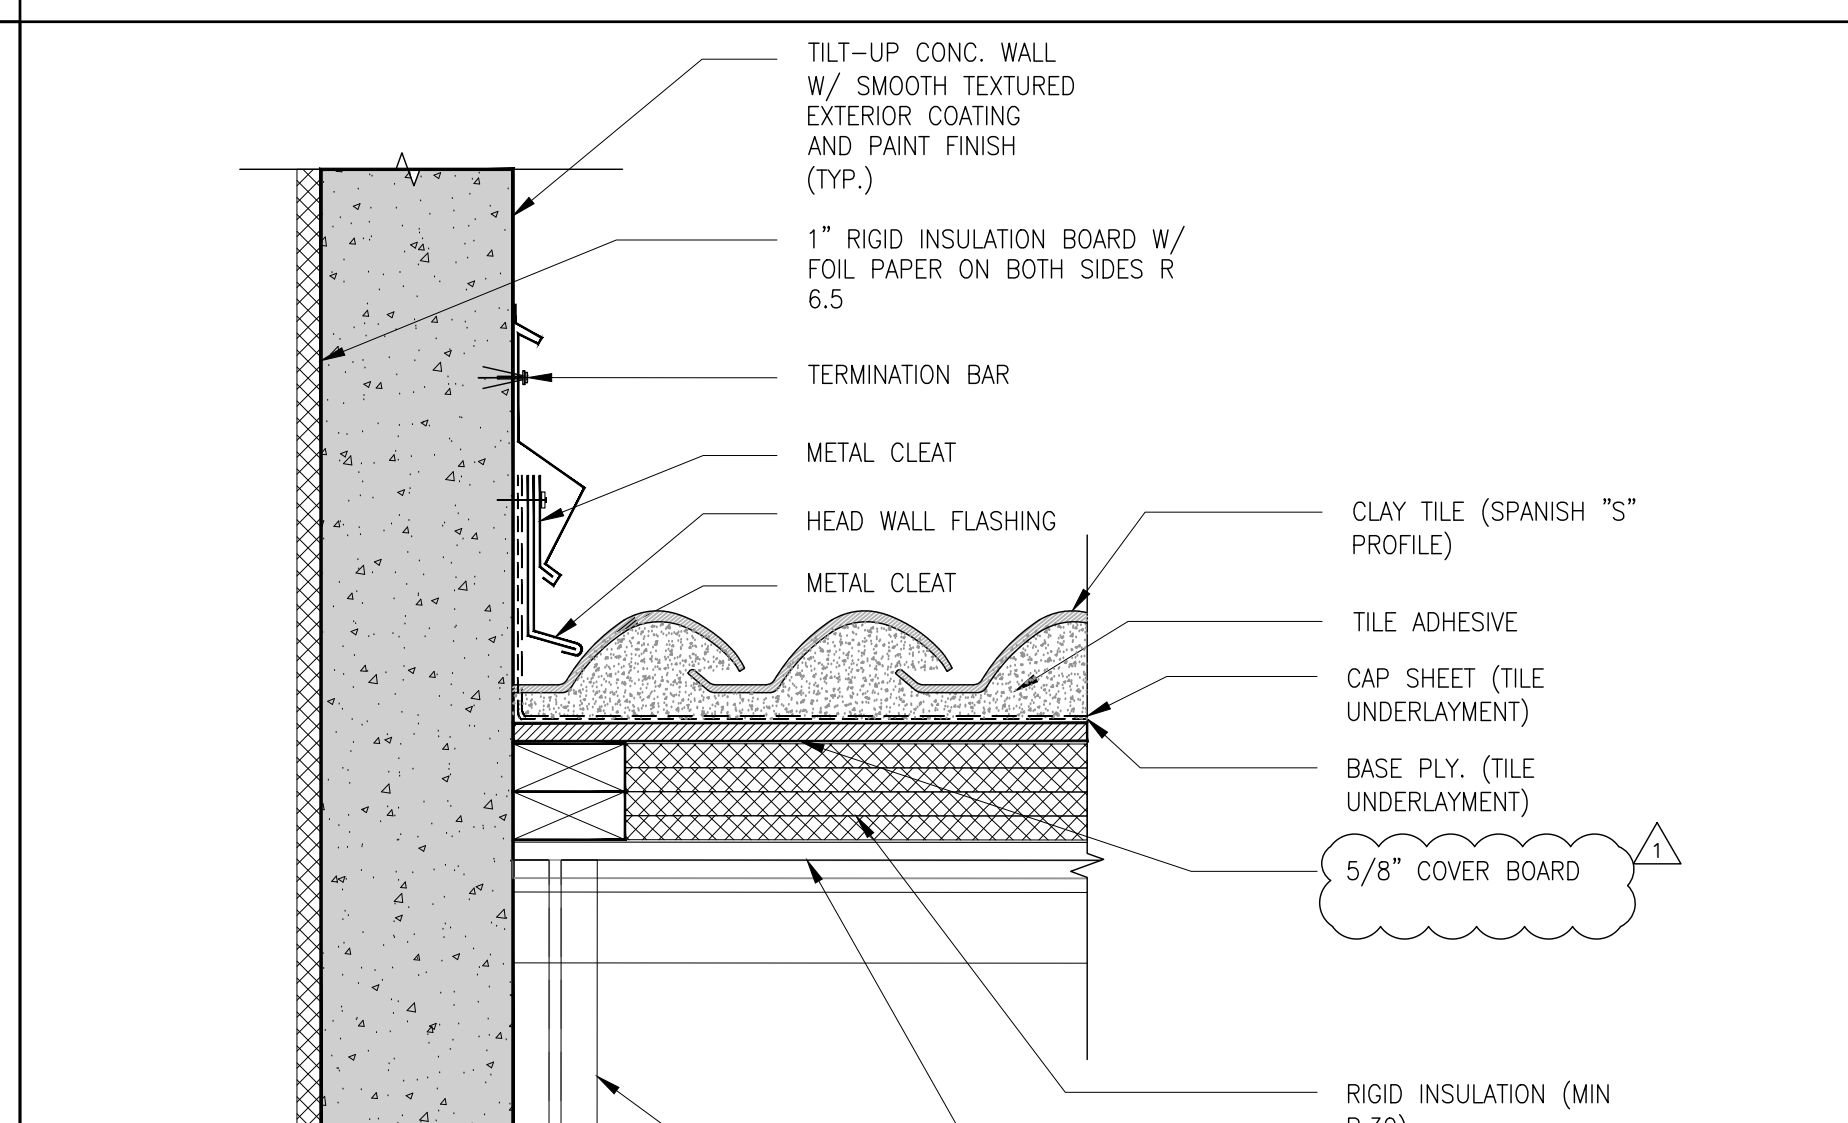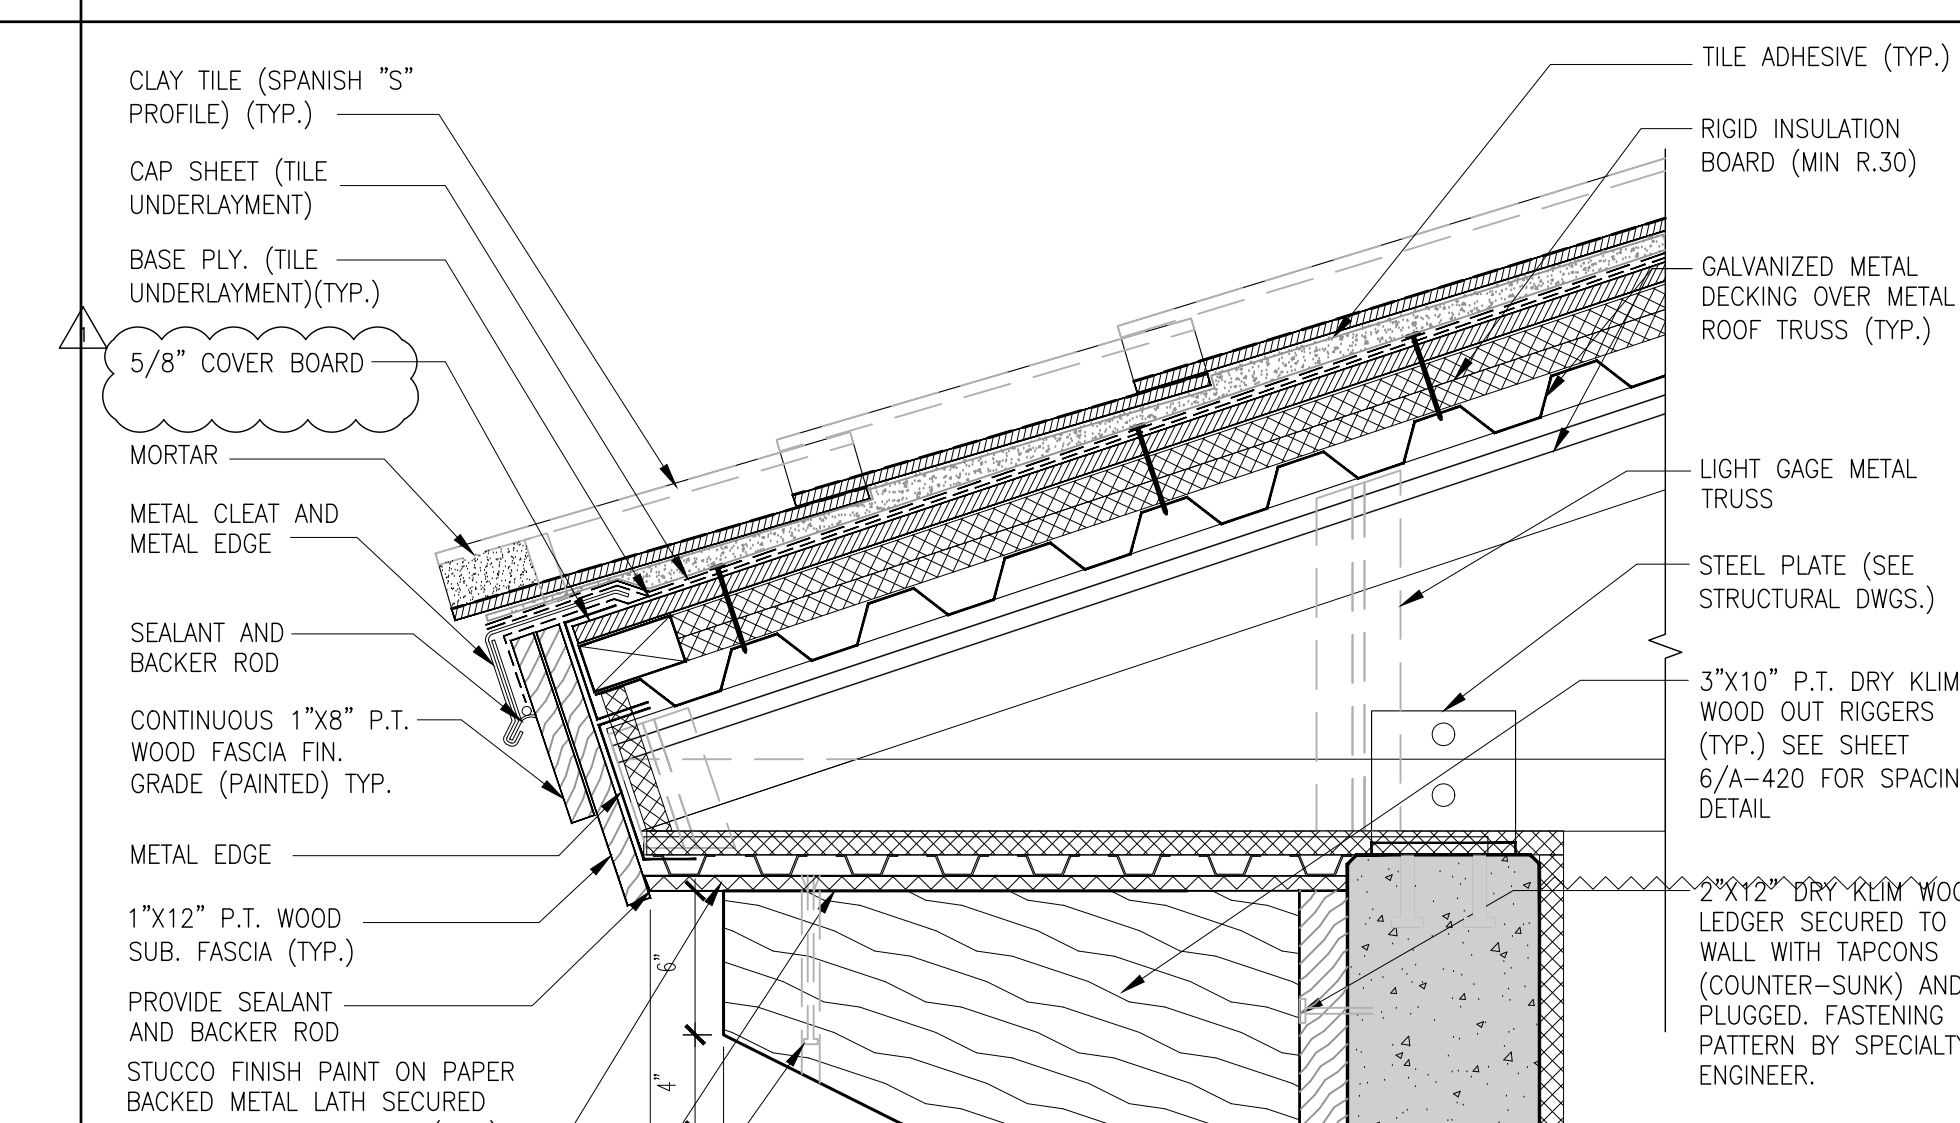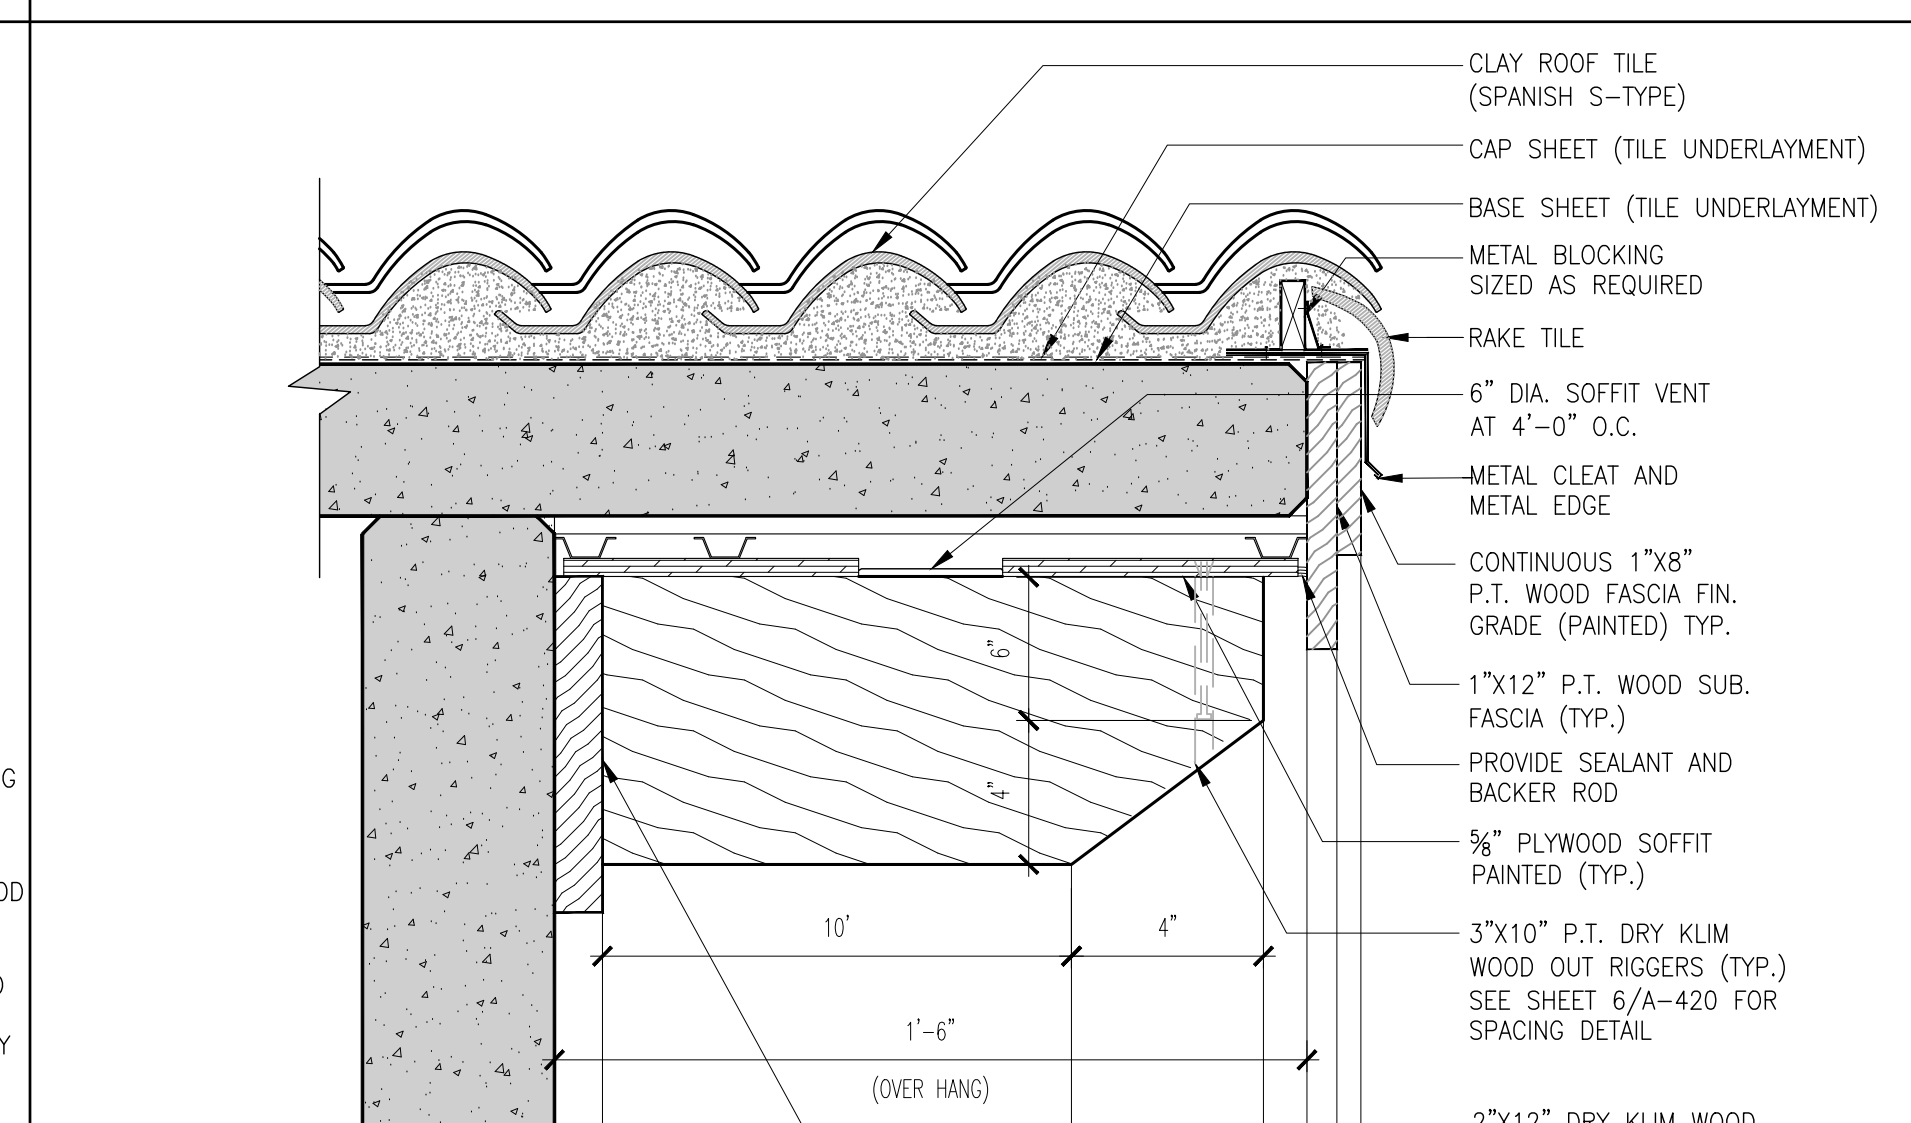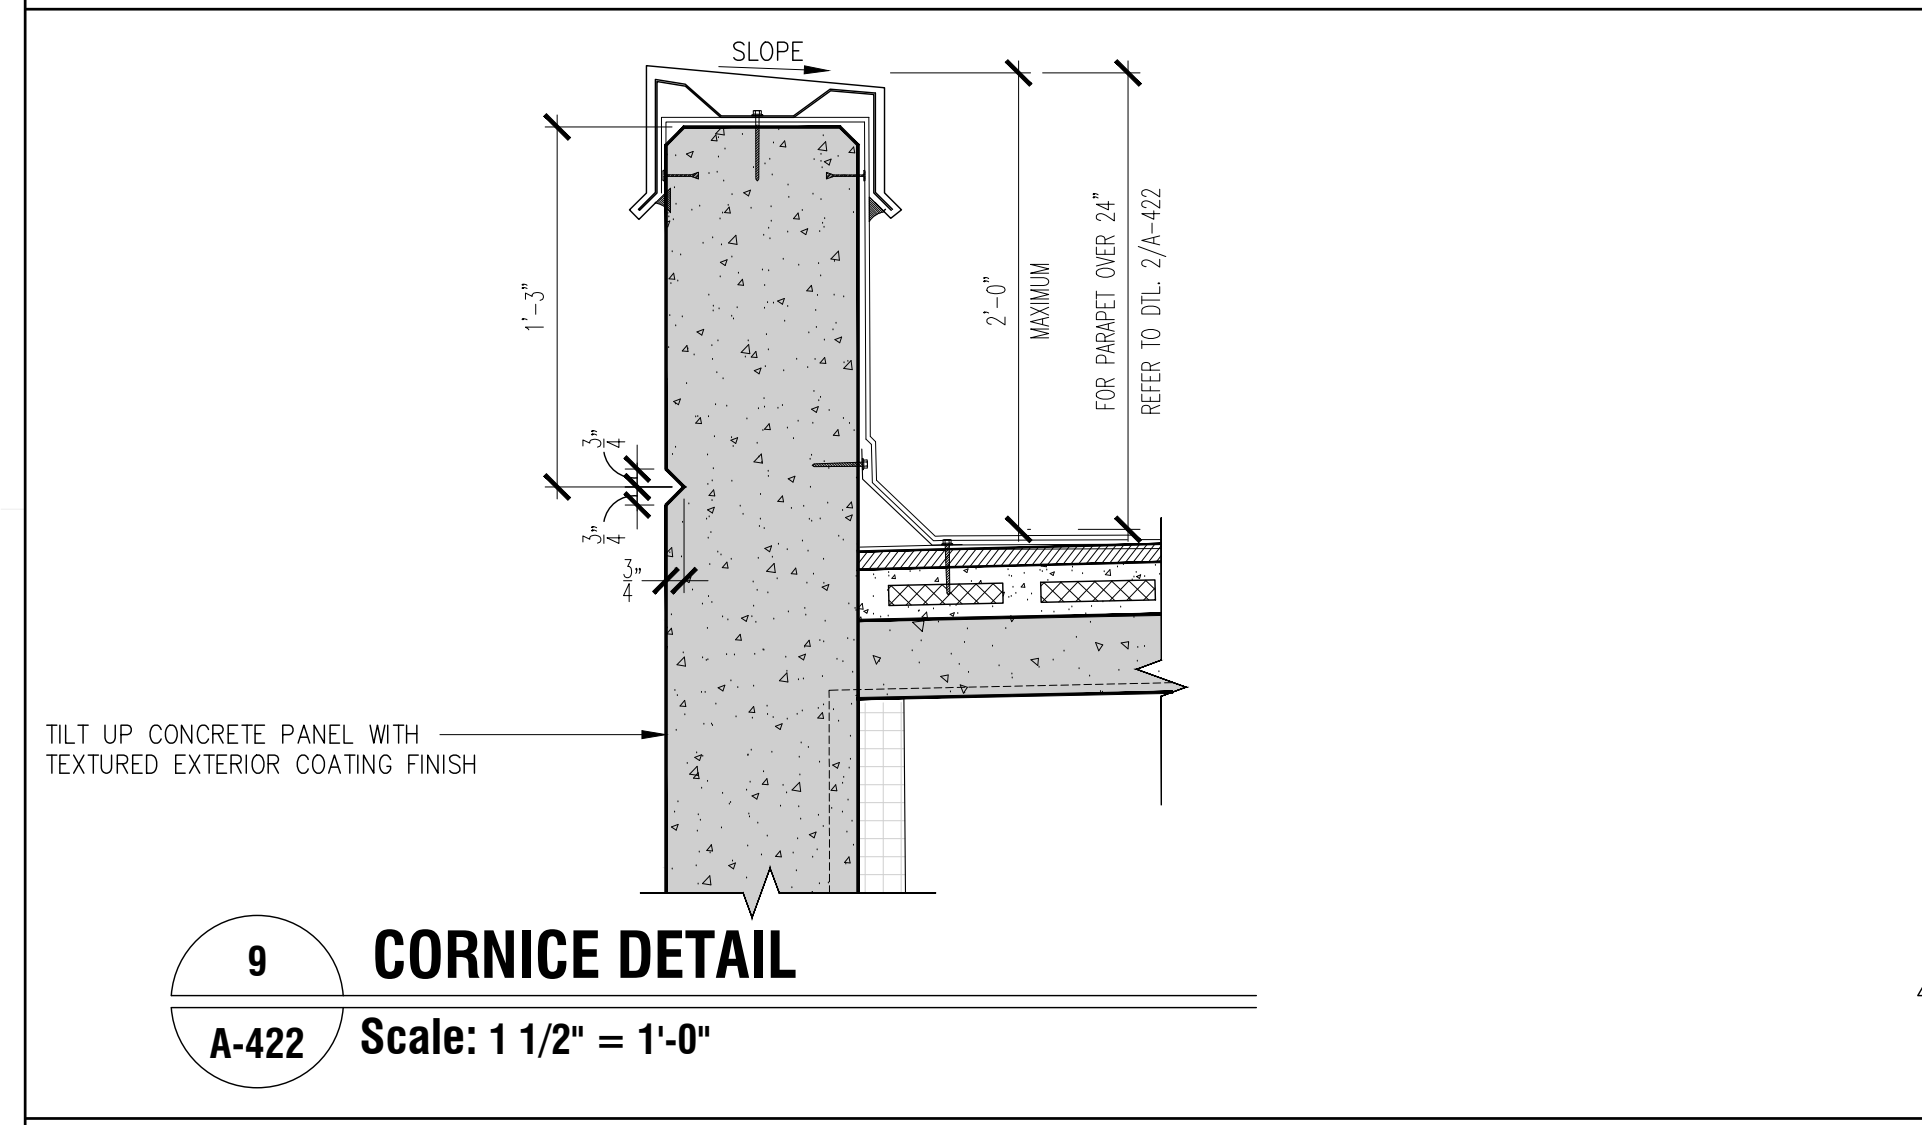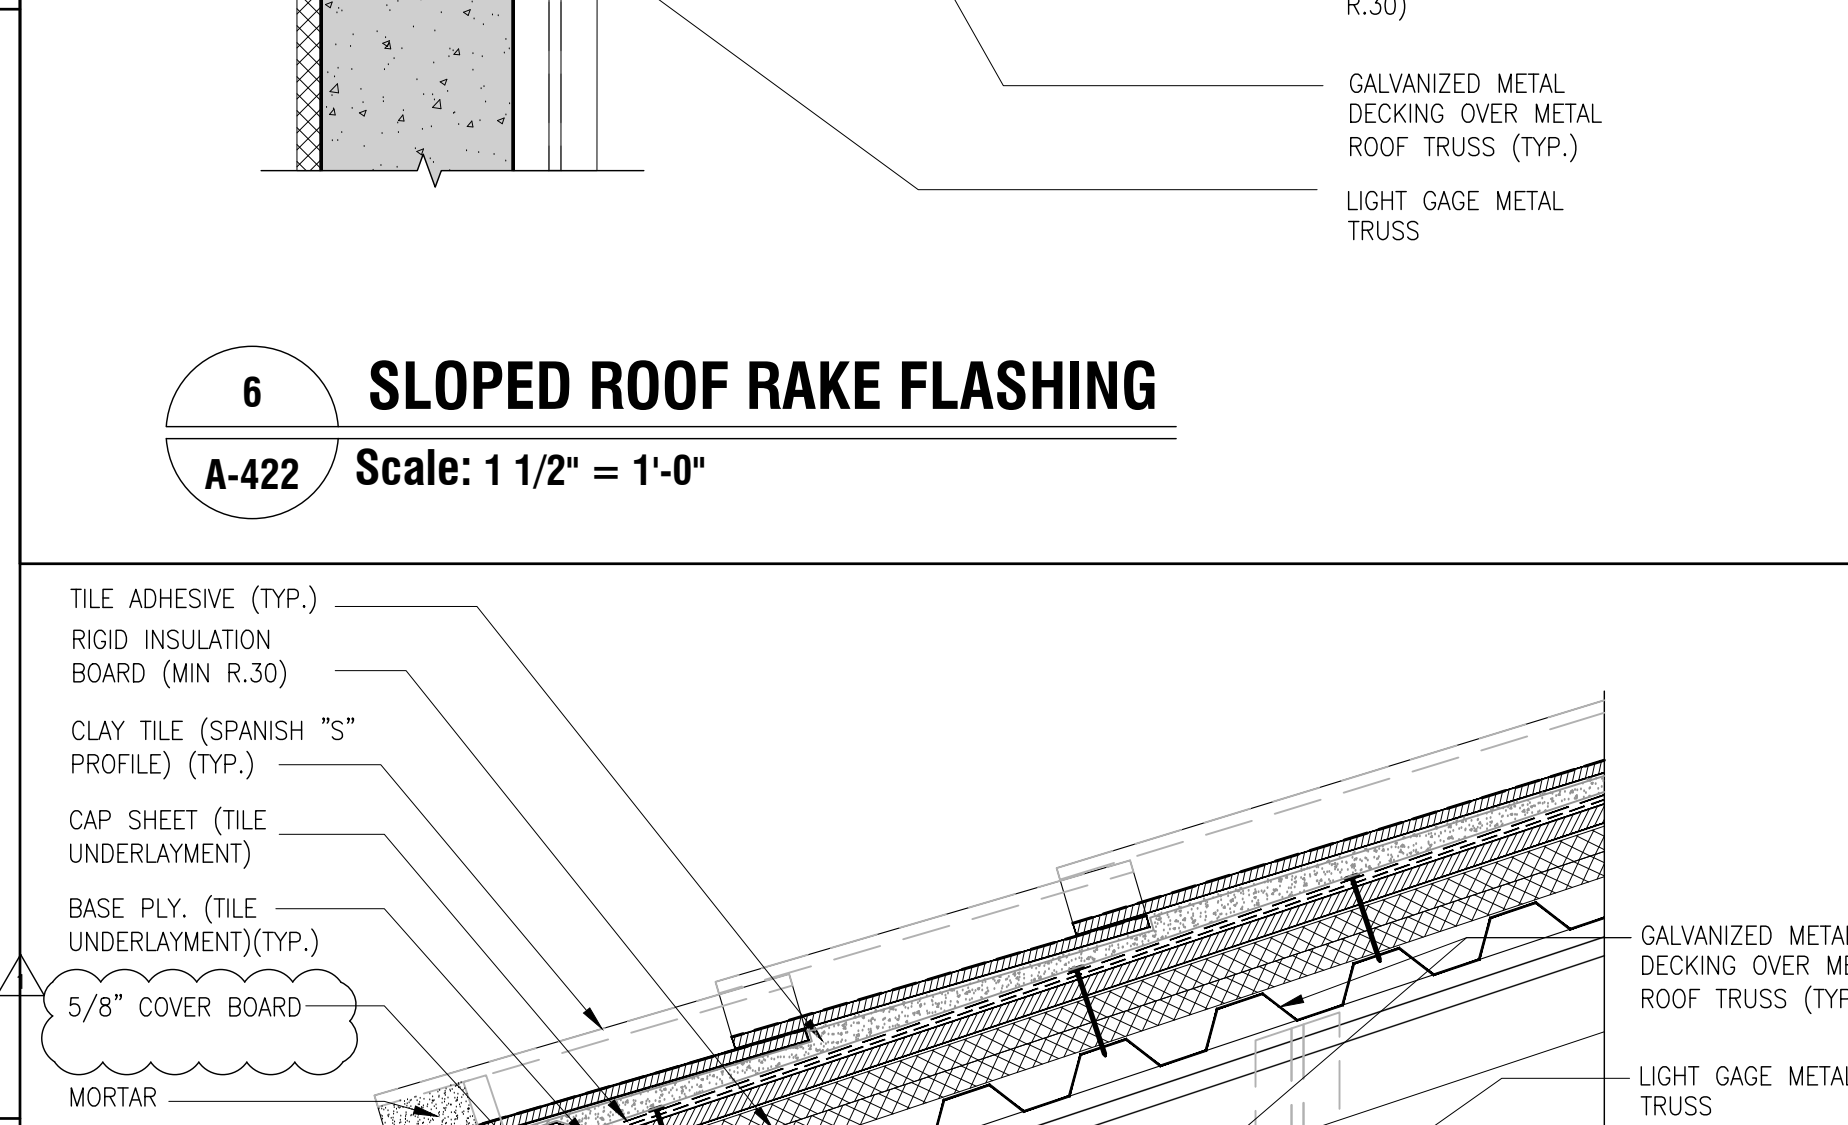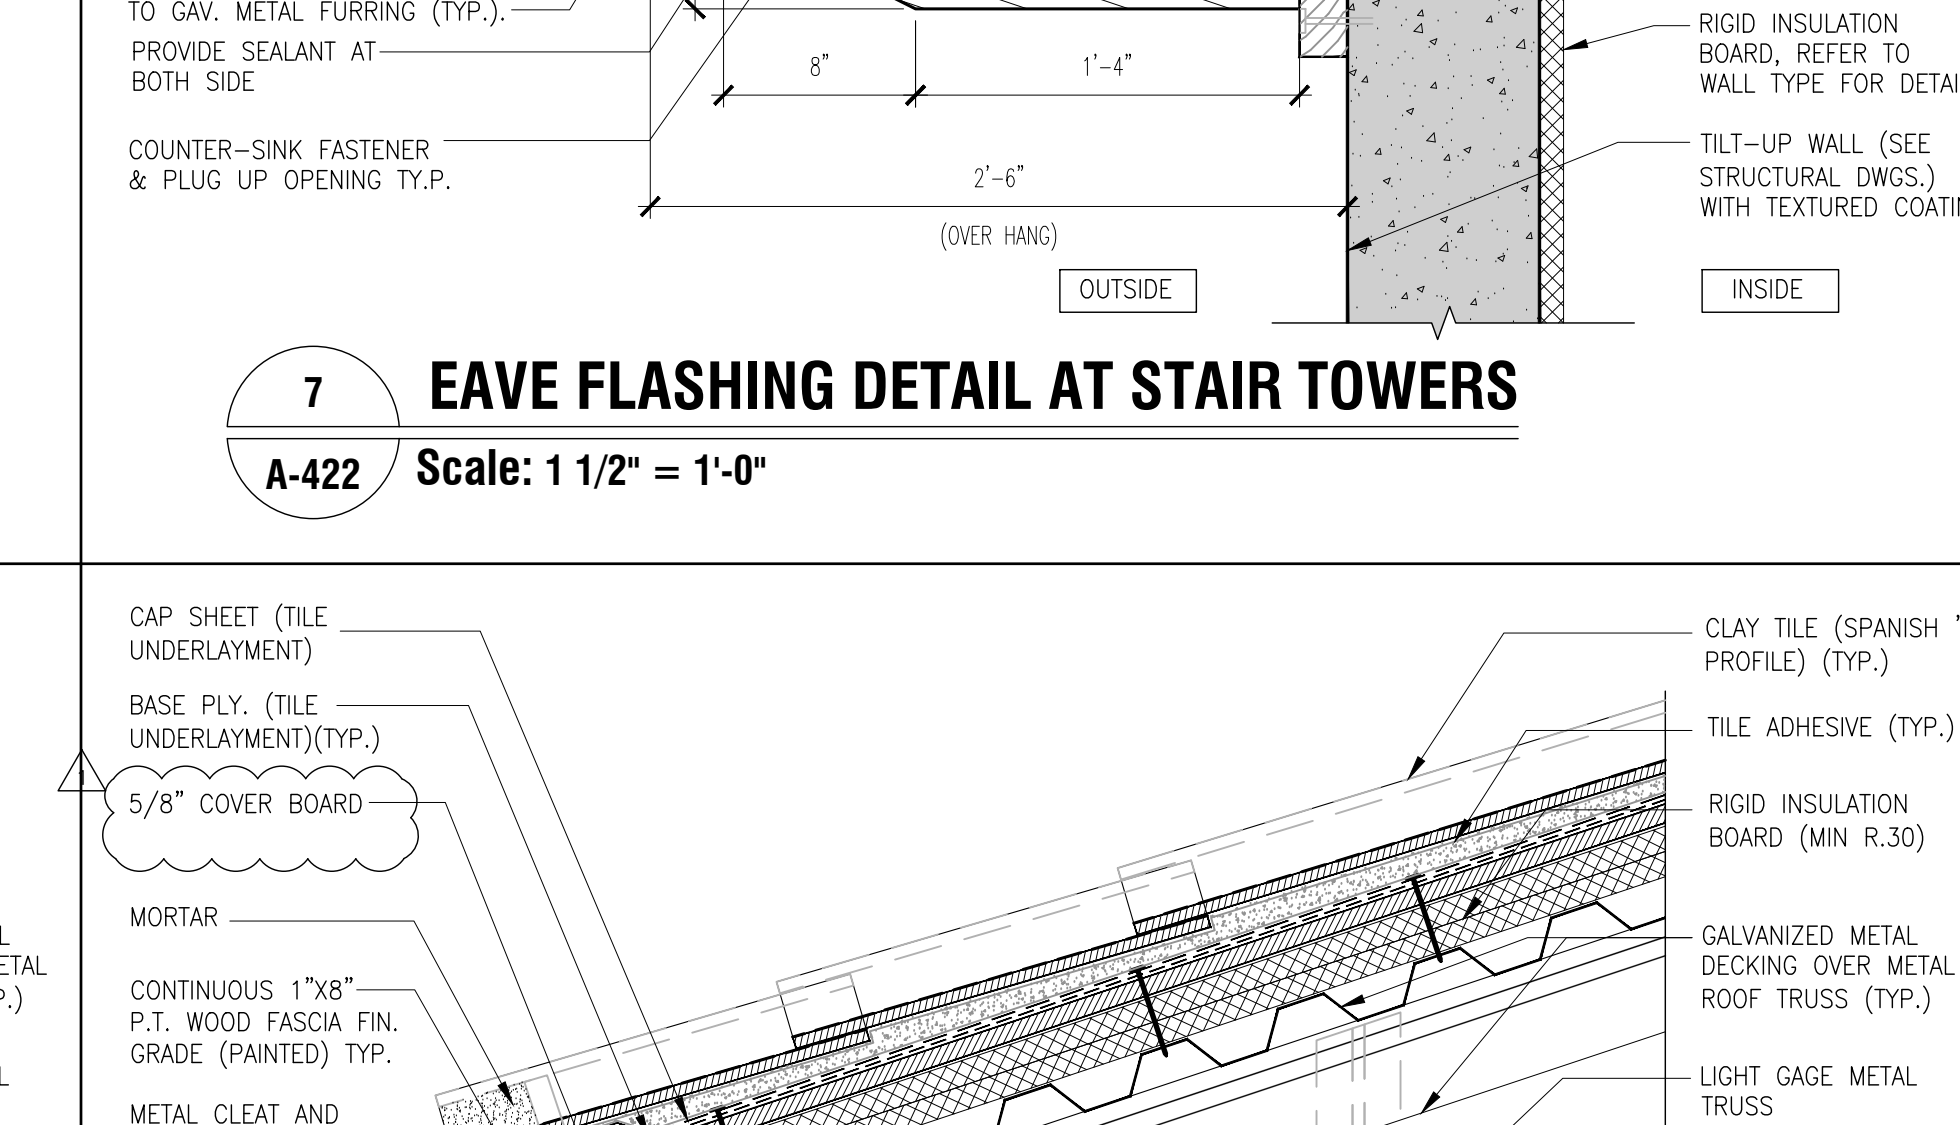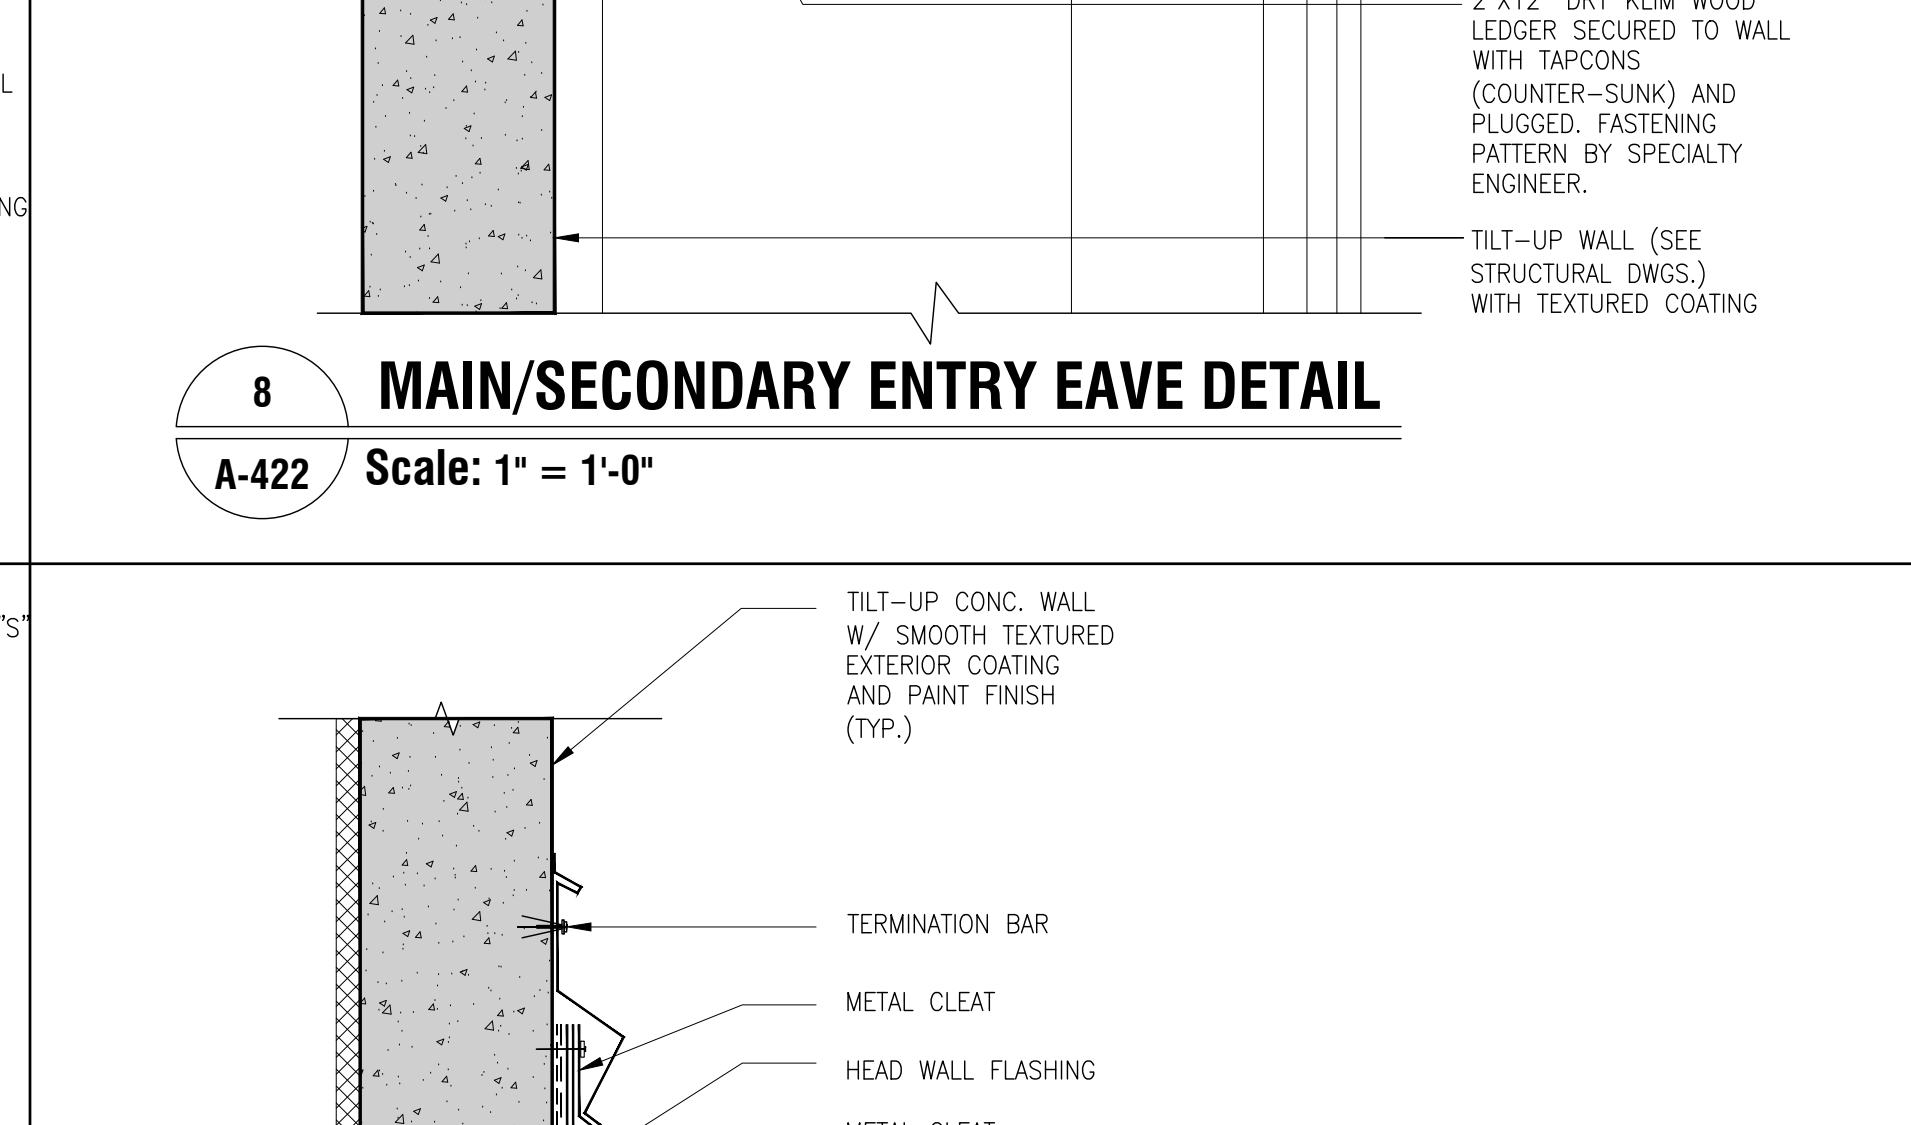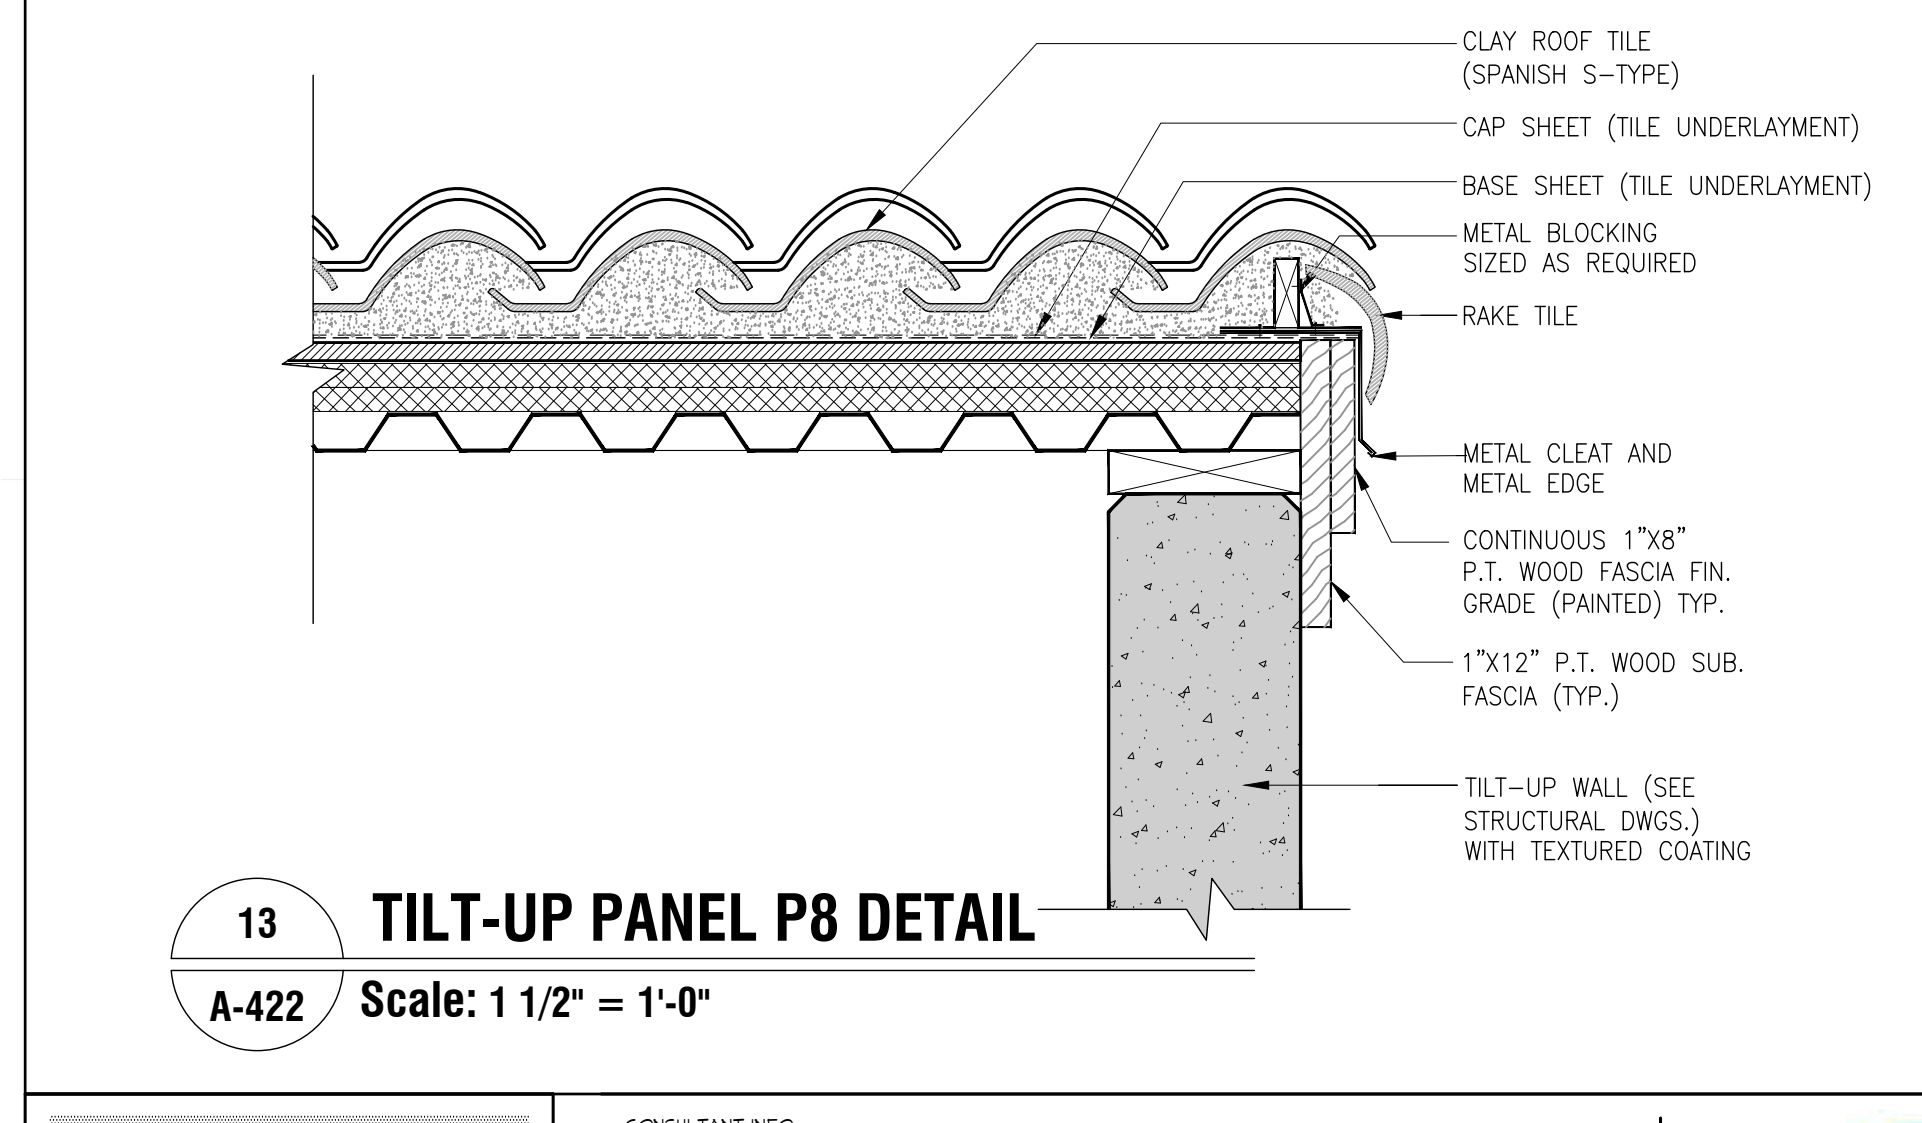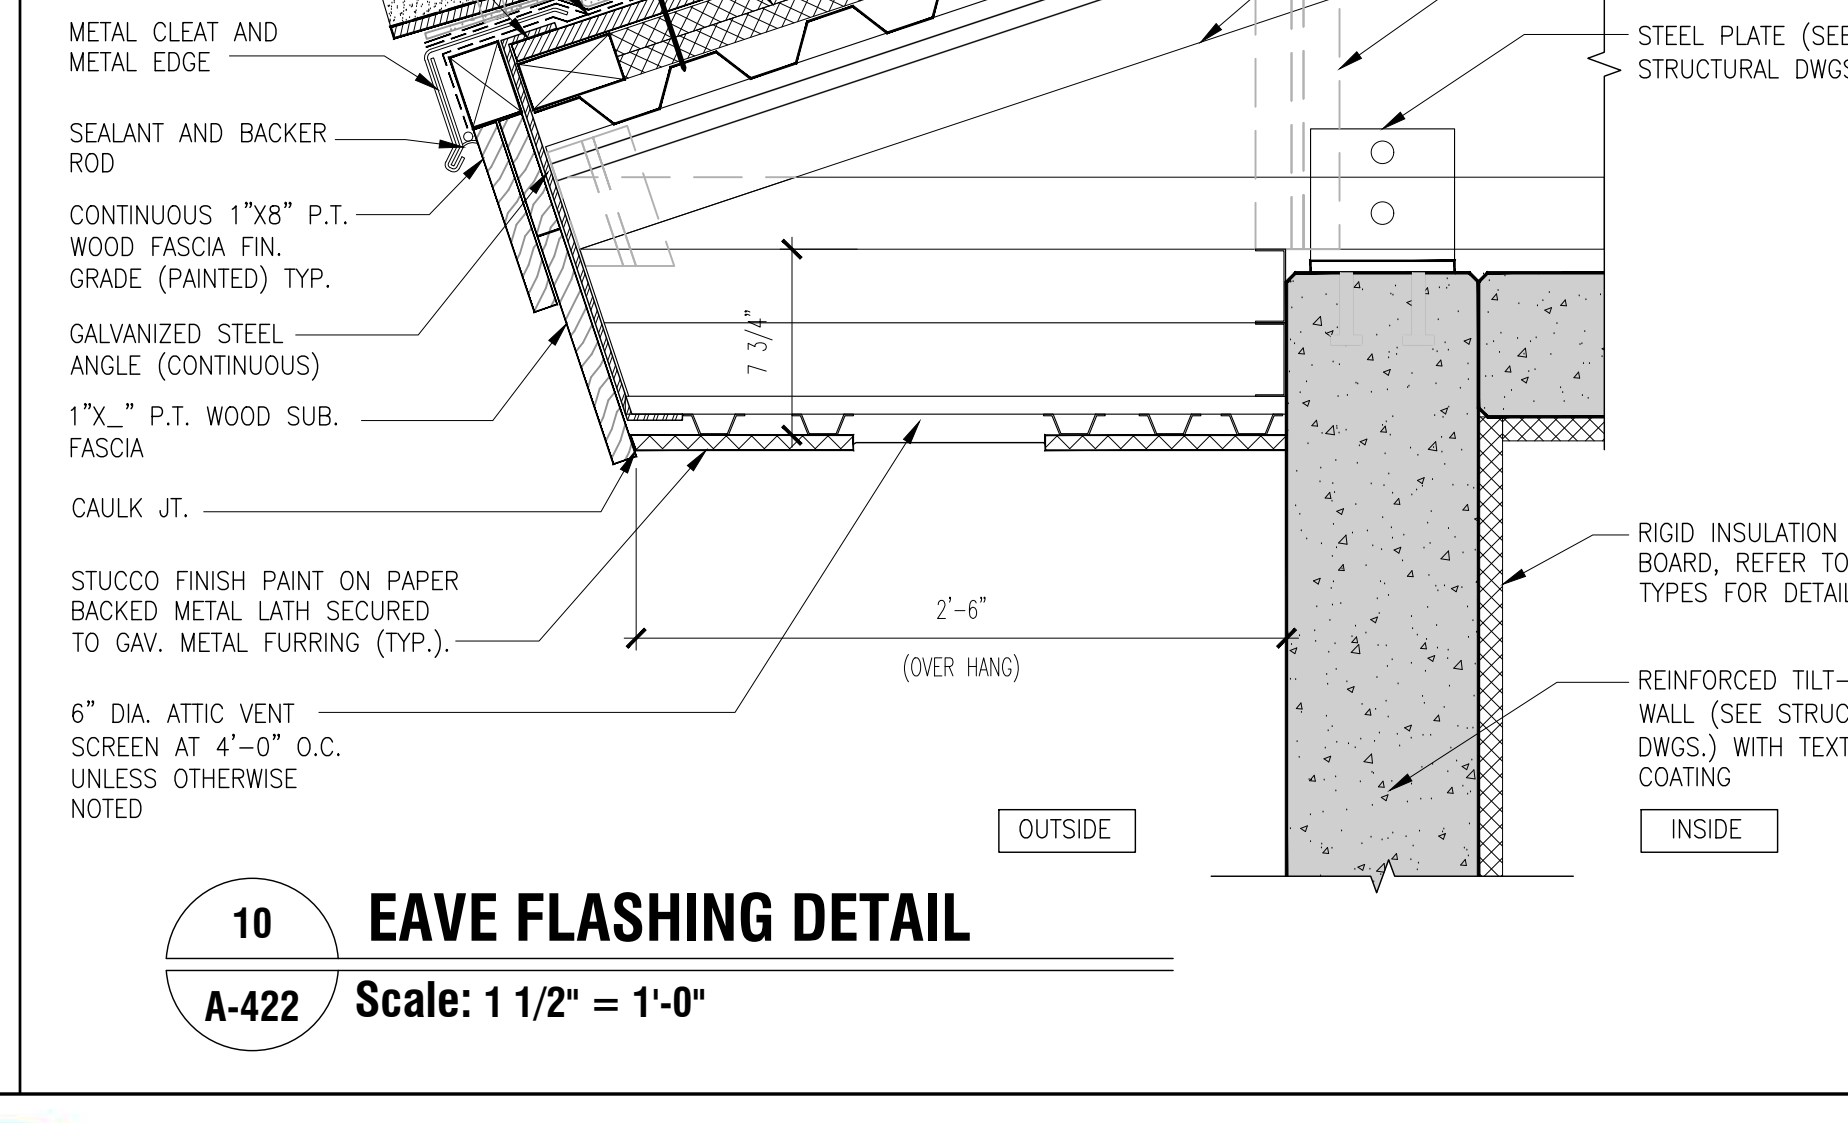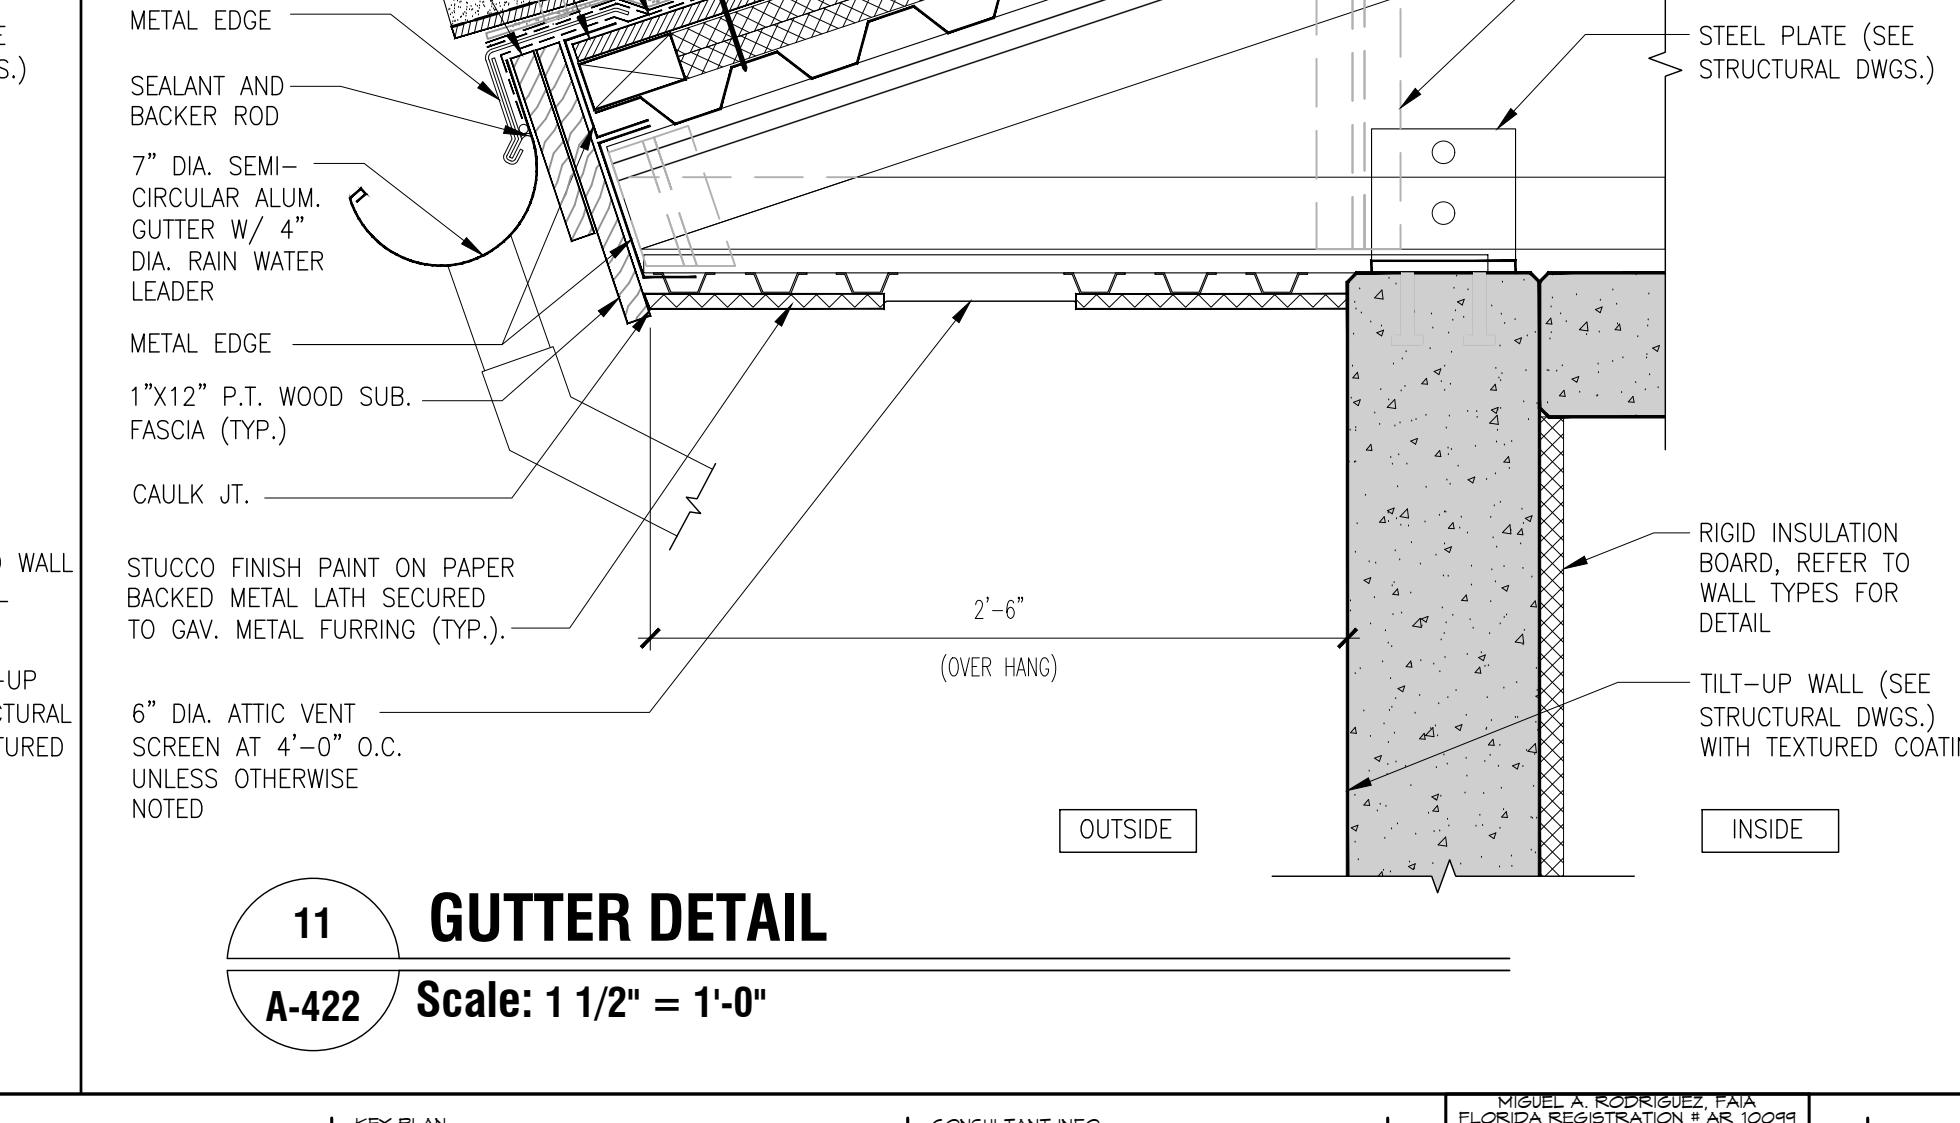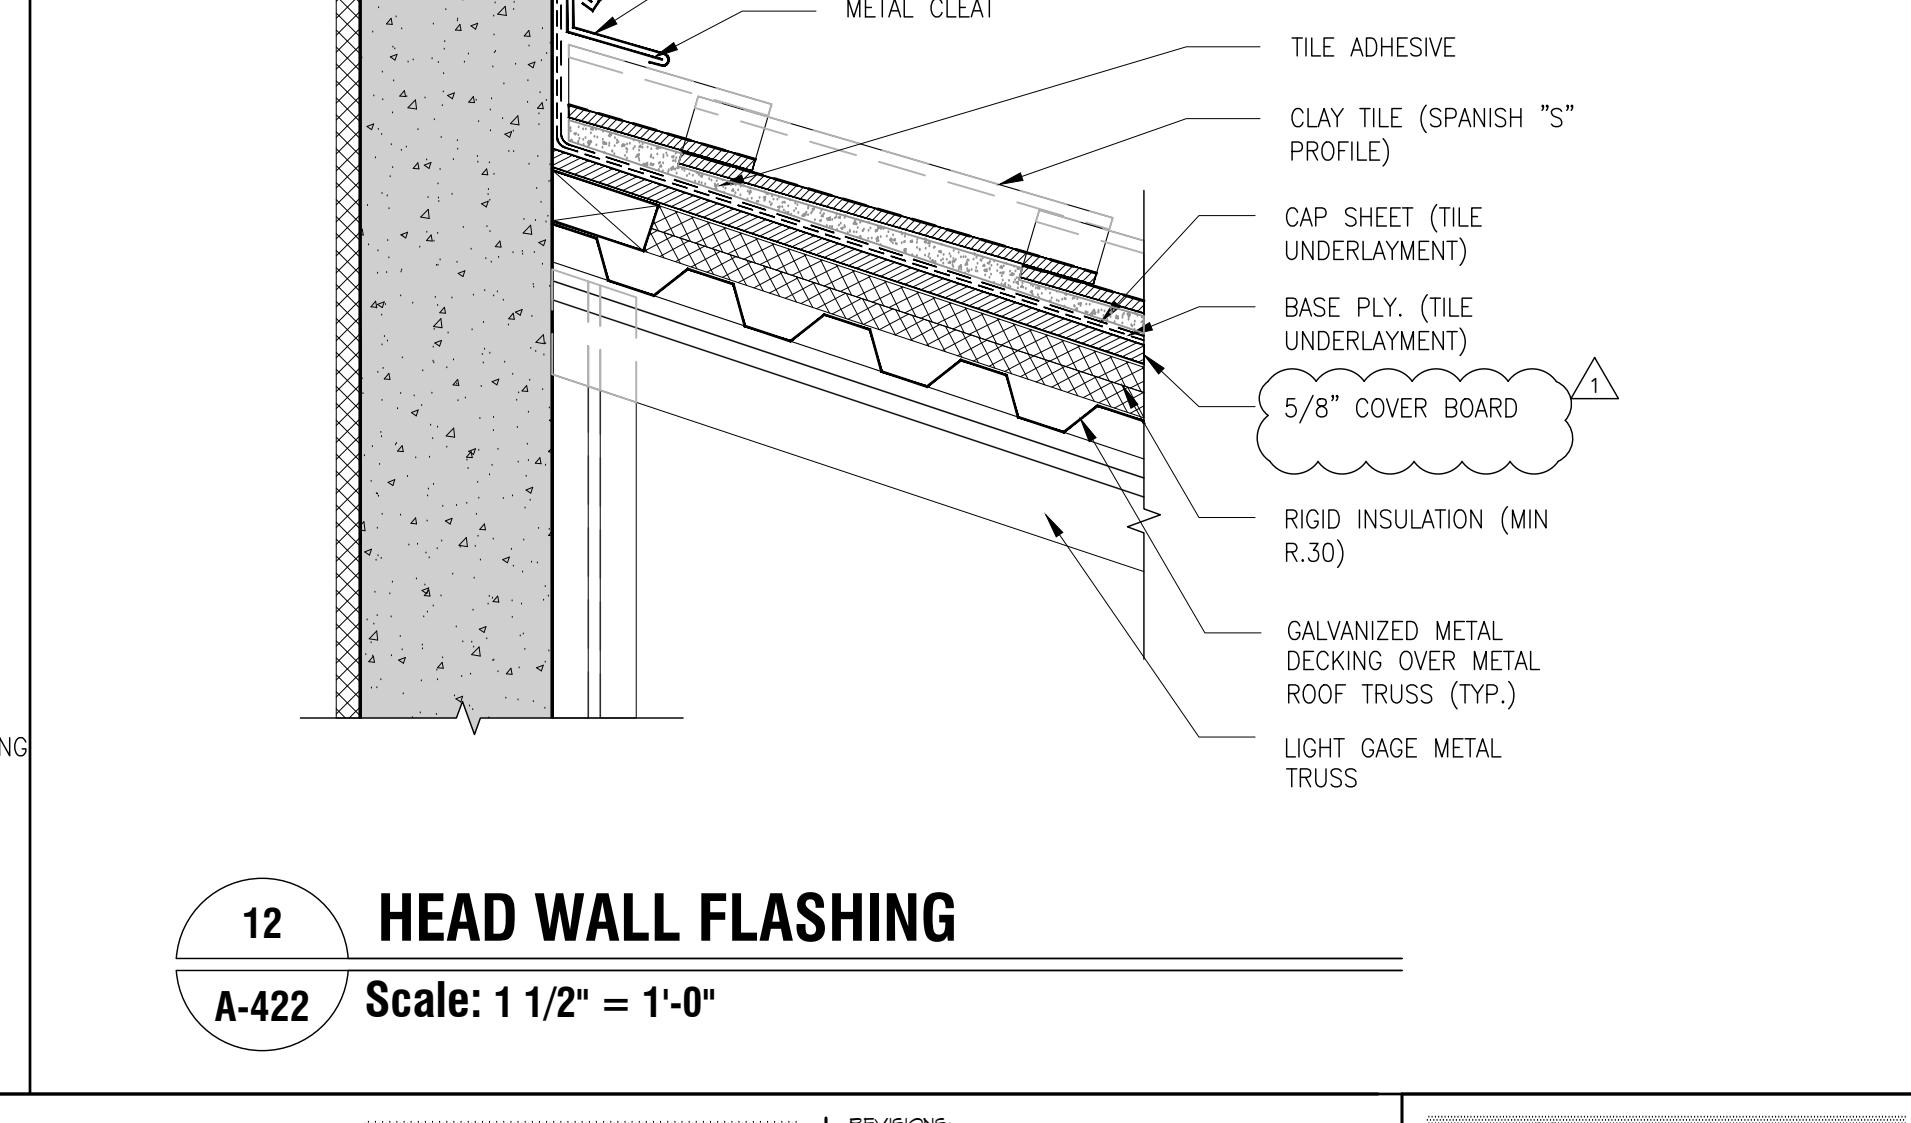

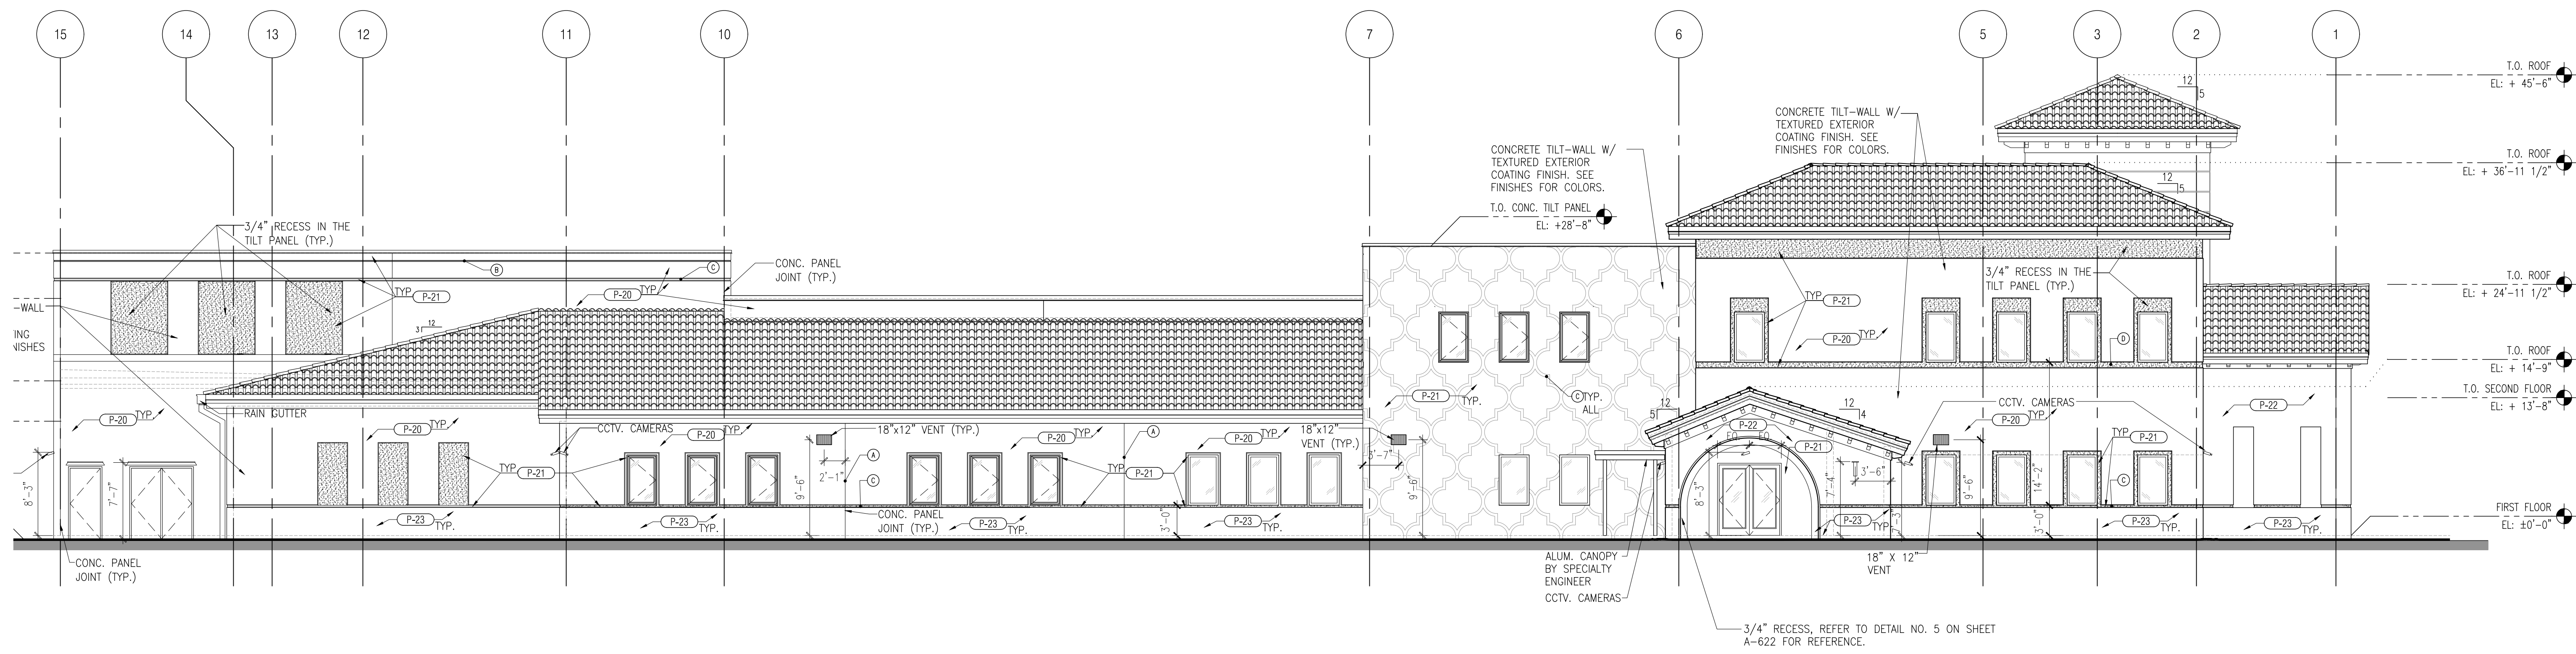


1 BUILDING ELEVATION - NORTH
A-501 Scale: 1/8" = 1'-0"

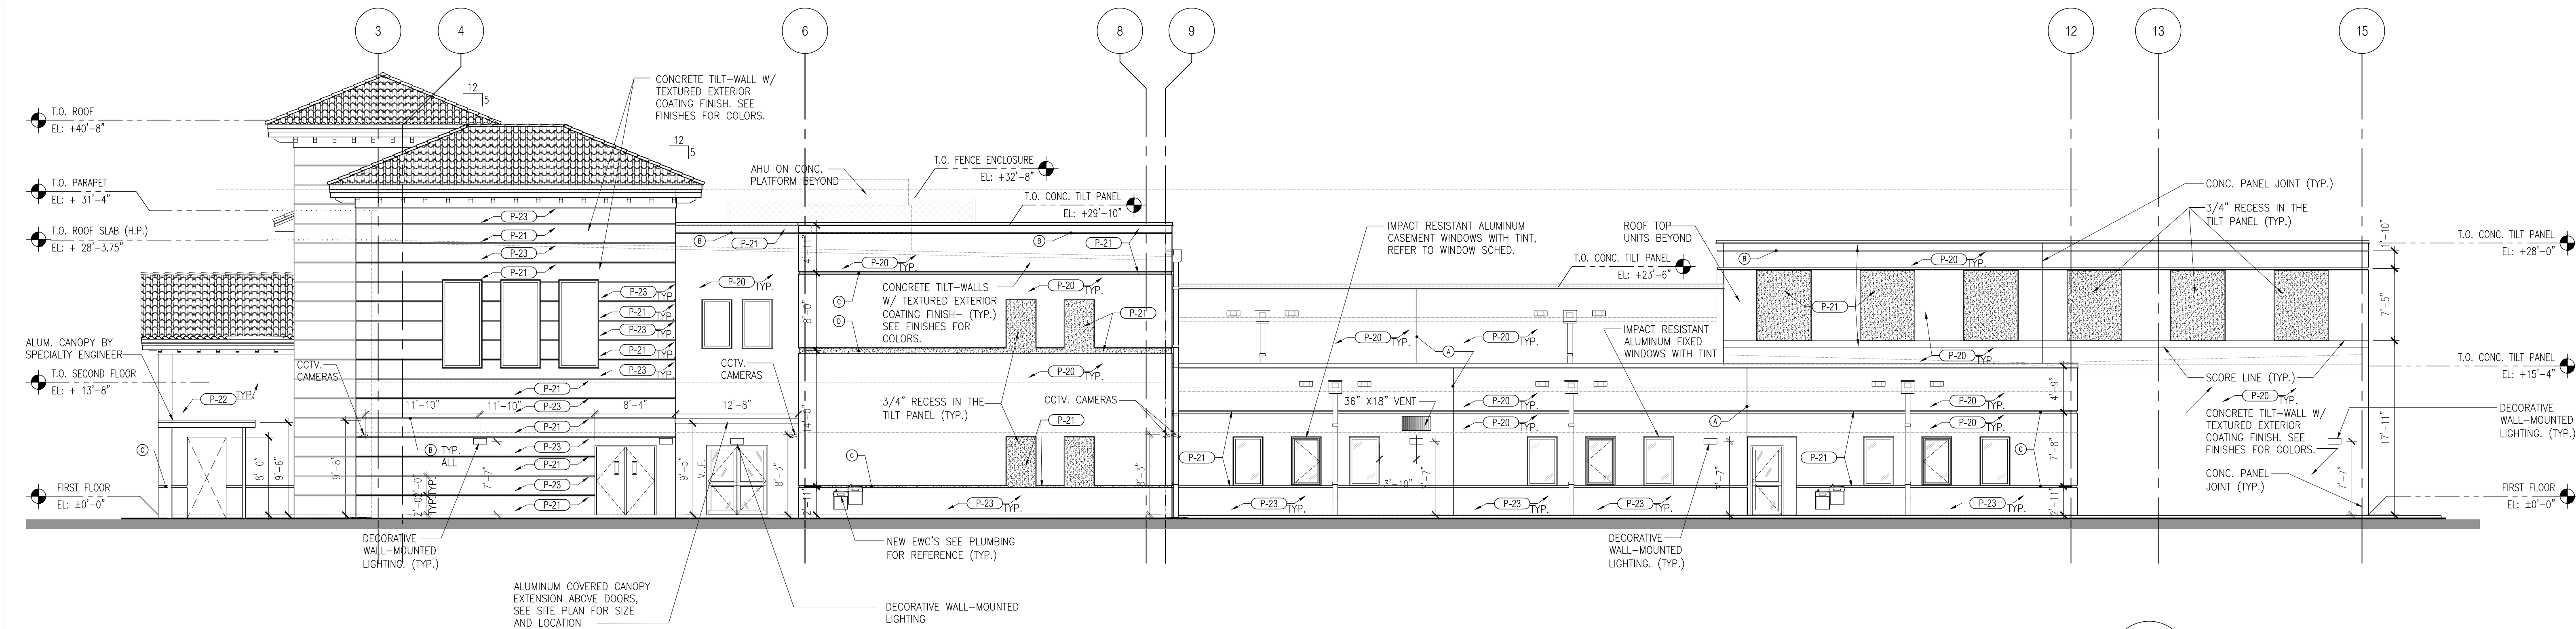

2 BUILDING ELEVATION - SOUTH
A-501 Scale: 1/8" = 1'-0"

ELEVATION LEGEND

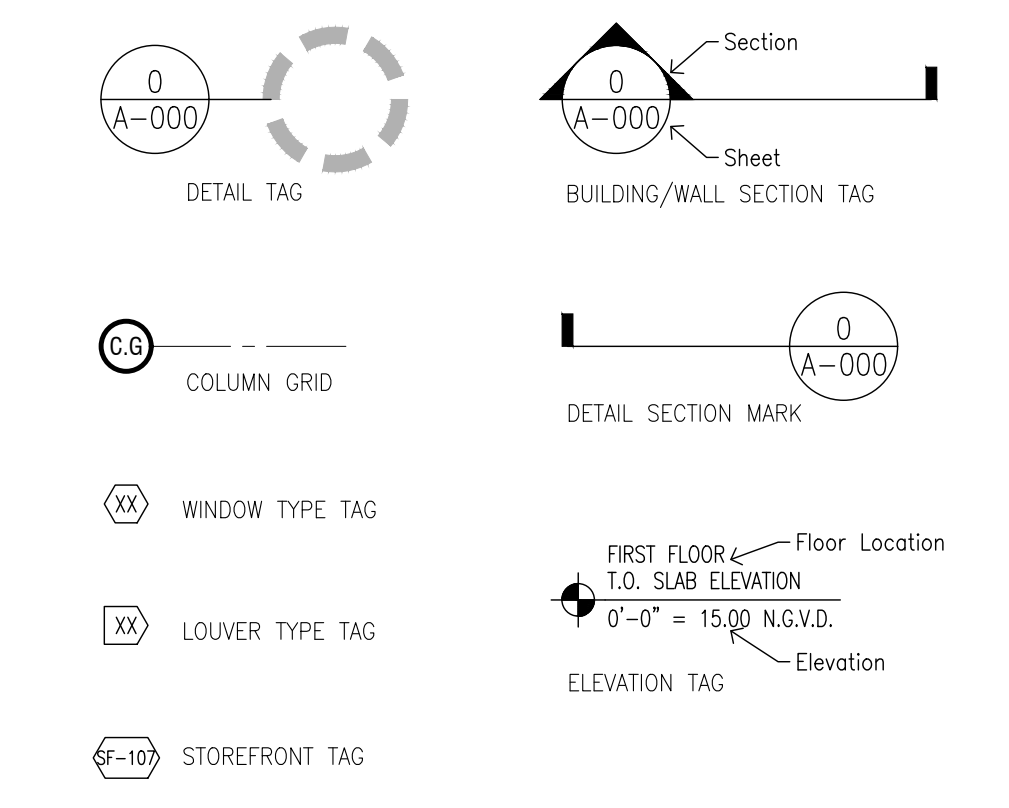


EXTERIOR FINISH BASIS OF DESIGN

MATERIAL	BASIS OF DESIGN
P-20 PAINT (FIELD)	2167-60 SWEET SALMON BENJAMIN MOORE
P-21 ACCENT PAINT	2167-40 TOFFEE ORANGE BENJAMIN MOORE
P-22 ACCENT PAINT	2162-40 PEANUT SHELL BENJAMIN MOORE
TRIM1	WINDOWS/DOORS/DETAIL COLOR TO BE DETERMINED
TRIM2	ROOF FASCIA/SOFFIT/DENTILS COLOR TO BE DETERMINED
WINDOW/DOOR FRAME AND ACCESSORIES	FINISH TO BE DETERMINED
EXTERIOR GLAZING	TINTED - LOW-E COATING FINISH TO BE DETERMINED
S-TILE	CLAY/PAINT FINISH COLOR TO BE DETERMINED
ROOF/SLOPED TILE	CLAY/PAINT FINISH COLOR TO BE DETERMINED
ROOF ACCESSORIES	(MATCH ROOF)
SIGNAGE/LETTERS	COLOR TO BE DETERMINED
LIGHT FIXTURES	FINISH TO MATCH WINDOW FRAMES

ELEVATION GENERAL NOTES

- SEE STRUCTURAL DRAWINGS FOR ALL OPENING PROTECTIVE AND CLADDING DESIGN PRESSURES.
- REFER TO FLOOR PLAN DRAWINGS FOR ADDITIONAL DIMENSIONS.
- CONTRACTOR TO COORDINATE WITH SHEET SERIES "200 SERIES" FLOOR PLANS, "900 SERIES" FINISH PLANS AND "LS" LIFE SAFETY PLAN FOR ALL WALL TYPES, PARTITION CONSTRUCTION AND OPENING PROTECTION RATINGS.
- ALL EXTERIOR OPENINGS ARE TO BE PROTECTED WITH HURRICANE IMPACT RESISTANT TESTED/NOA ASSEMBLIES MEETING DESIGN PRESSURES INDICATED IN STRUCTURAL DRAWINGS.
- CONTRACTOR TO COORDINATE ALL AREAS AND MATERIALS WITH SPECIAL CONSIDERATION FOR ITEMS WHICH ALIGN AND COURSE WITH FINISH MATERIALS (AS APPLICABLE). ALL CORNICES SHALL BE NOTICED TO ARCHITECT OR RECORD UPON DISCOVERY, WITH OPTION FOR RESOLUTION AS PRESENTED BY CONTRACTOR.
- EXTERIOR ALUMINUM STOREFRONT SYSTEMS ARE DESIGNED TO BE SET WITHIN ALUMINUM CLAD STRUCTURAL STEEL FRAME (AS APPROPRIATE). ALL EXPOSED STEEL AT THESE LOCATIONS ARE TO BE COVERED WITH ALUMINUM (WITH FINISH TO MATCH WINDOW FRAME MATERIAL) AND FLASHED SO AS TO PREVENT THE INTRUSION OF AIR OR WATER.
- ALL EXTERIOR AND INTERIOR LIGHTING, EXIT SIGNS AND FIXTURES SHALL HAVE CONCEALED CONDUIT AND HOUSINGS.
- ALL EXTERIOR TILT-CONCRETE PANELS ARE TO BE SEALED AT BOTH SIDES WITH FULL CONTINUOUS BACKER ROD AND SEALANT. PROVIDE WEEPS AT EACH LOCATION IN ACCORDANCE WITH MANUFACTURER'S RECOMMENDATIONS.
- LOCATE EXPANSION/CONTROL JOINTS PER DRAWINGS PROVIDED AND INDUSTRY STANDARD RECOMMENDATIONS. SEAL ALL JOINTS WITH PROPER BACKING MATERIAL AND POLYURETHANE SEALANT OR PREFORMED FOAM AND RUBBER EXPANSION JOINT CLOSURE. JOINT CLOSURE/SEALANT SHALL MATCH THE COLOR OF THE MASONRY.
- ALL MASONRY TO CREATE A UNIFORM APPEARANCE WHEN INSTALLED.
- ALL THROUGH WALL FLASHING SHALL BE INSTALLED IN ACCORDANCE WITH ALL APPLICABLE BIA TECHNICAL NOTES AND SMACNA REQUIREMENTS. EXTEND METAL DRIP EDGE FLASHING BEYOND THE WALL PLANE USE A 1/4\"/>
- VENEER REINFORCING SHALL BE GALVANIZED TO G90 COATING AND SUFFICIENT SIZE TO ELIMINATE DAMAGE TO VENEER LAYER FROM WIND AND OTHER LIVE AND DEAD LOADS IMPOSED.

PANEL JOINTS

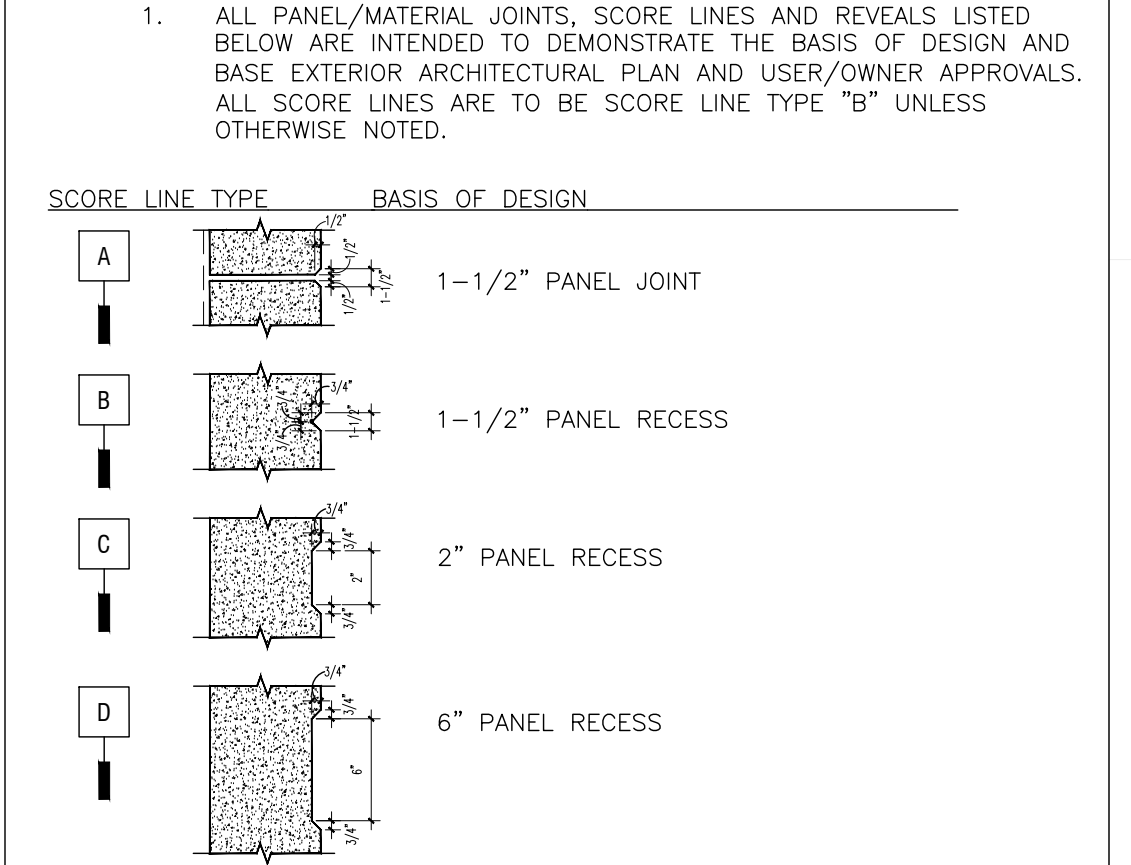


CHECKED BY: LR	DRAWN BY: C.V.
-------------------	-------------------

CONSULTANT INFO:

MIAMI-DADE COUNTY
giving our students the world
PUBLIC SCHOOLS



NEW ELEMENTARY SCHOOL (K-5)
VENETIAN PARC WEST
SOUTHWEST 157th AVENUE and 174th STREET
MIAMI, FL. 33187
MDCPS PROJECT No. 01892600

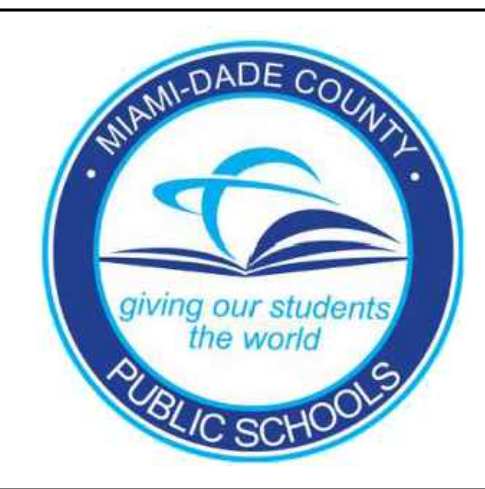

KEY PLAN

CONSULTANT INFO:


RODRIGUEZ ARCHITECTS INCORPORATED
2121 PONCE DE LEON BLVD. STE. 1010
CORAL GABLES, FL. 33134
TEL: (305) 448-3373
FAX: (305) 448-3374
A A C - 0 0 1 9 3 3

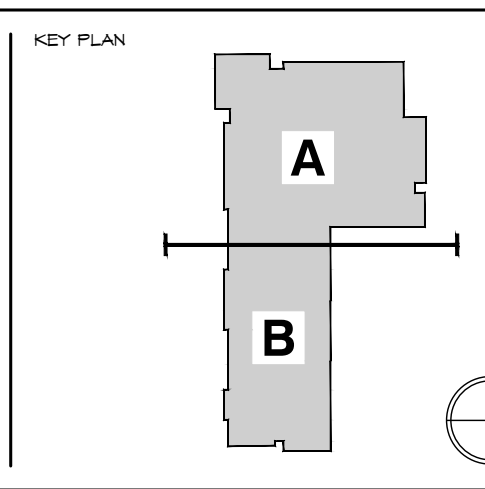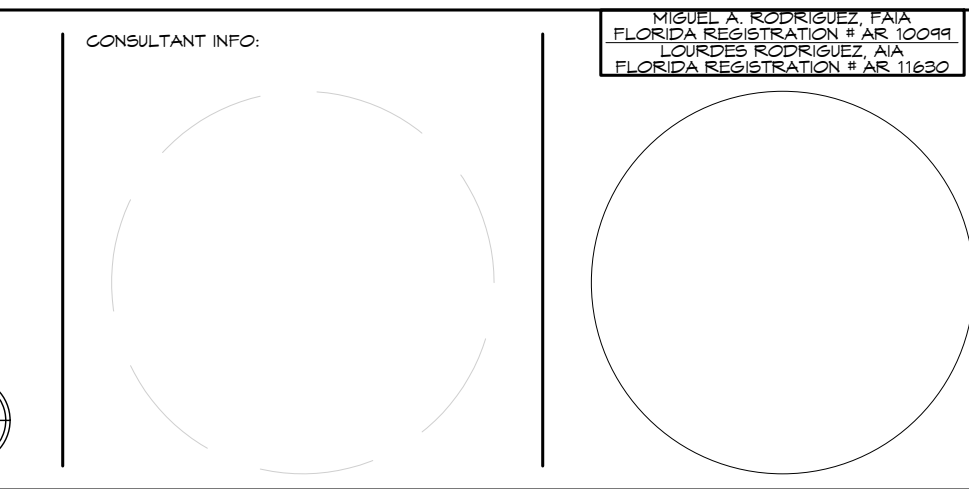

RAI


REVISIONS:

DRAWING TITLE: BUILDING ELEVATIONS	
SCALE AS NOTED	PROJECT NO. 1906
ISSUE DATE: 12/16/19	SHEET: A-501

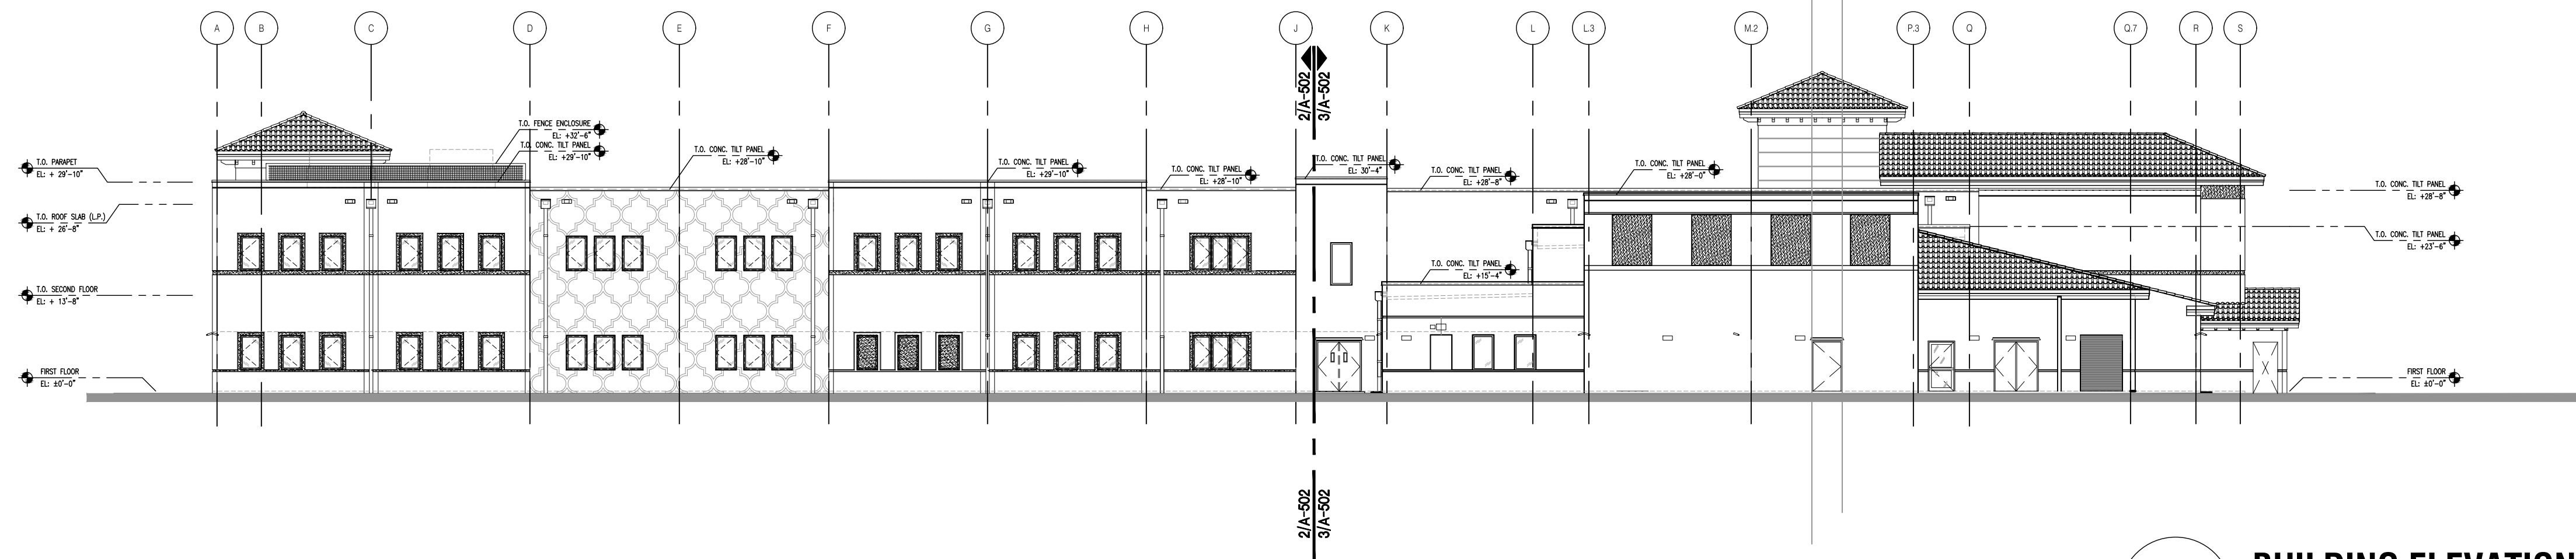


1 BUILDING ELEVATION - EAST

A-502 Scale: 1/16" = 1'-0"

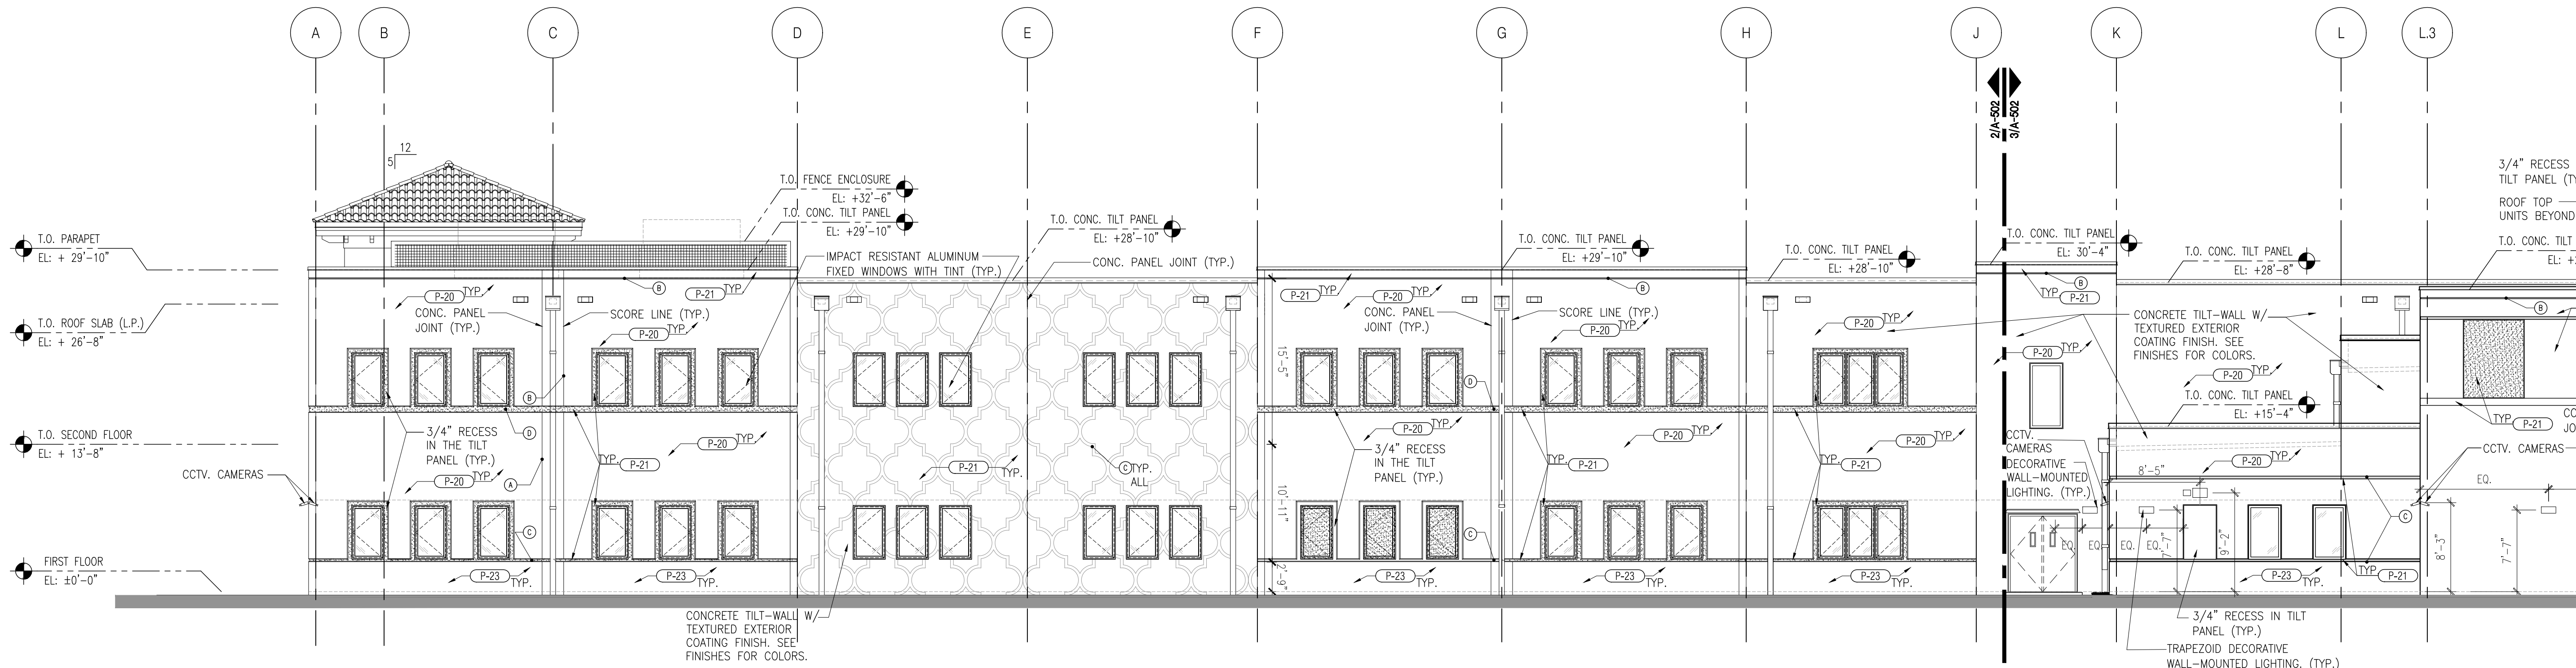

2 BUILDING ELEVATION - EAST


A-502 Scale: 1/8" = 1'-0"

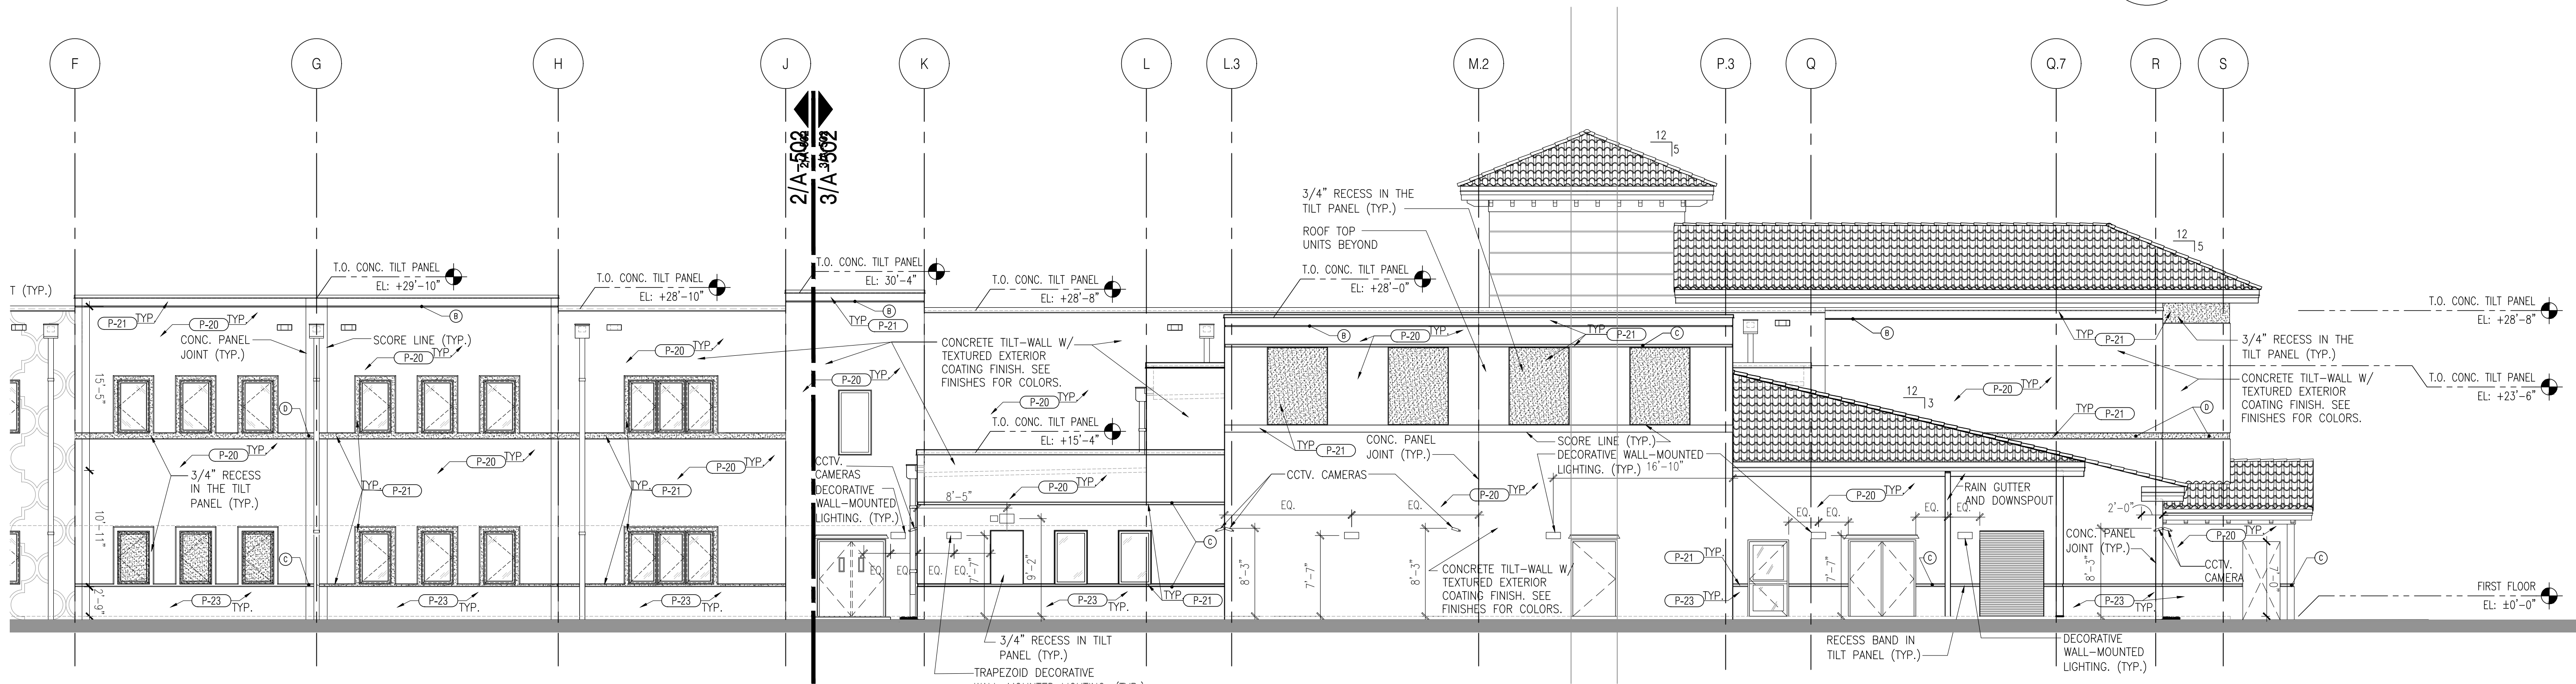

3 BUILDING ELEVATION - EAST

A-502 Scale: 1/8" = 1'-0"

ELEVATION LEGEND

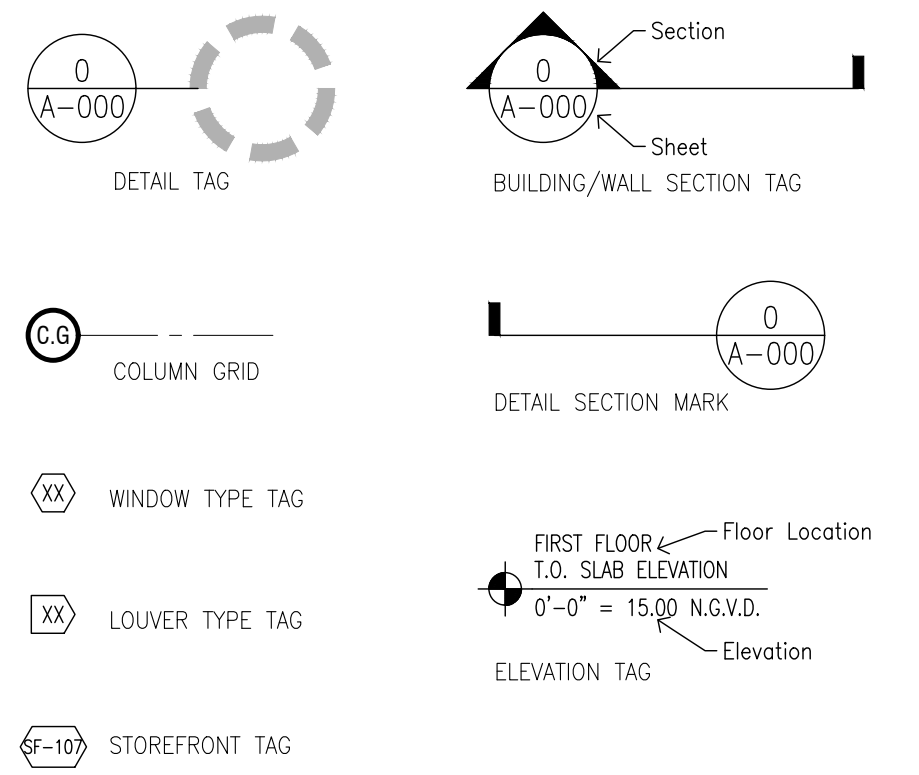

EXTERIOR FINISH BASIS OF DESIGN

1. ALL FINISHES LISTED BELOW ARE INTENDED TO DEMONSTRATE THE BASIS OF DESIGN AND APPROVALS PER PROVIDED DOWNTOWN DORAL STANDARDS AND USER/OWNER APPROVALS.

MATERIAL	BASIS OF DESIGN
P-20 PAINT (FIELD)	2167-60 SWEET SALMON BENJAMIN MOORE
P-21 ACCENT PAINT	2167-40 TOFFEE ORANGE BENJAMIN MOORE
P-22 ACCENT PAINT	2162-40 PEANUT SHELL BENJAMIN MOORE
TRIM1	WINDOWS/DOORS/DETAIL COLOR TO BE DETERMINED
TRIM2	ROOF FASCIA/SOFFIT/DENTILS COLOR TO BE DETERMINED
WINDOW/DOOR FRAME AND ACCESSORIES	FINISH TO BE DETERMINED
EXTERIOR GLAZING	TINTED - LOW-E COATING FINISH TO BE DETERMINED
S-TILE ROOF/SLOPED TILE	CLAY/PAINT FINISH COLOR TO BE DETERMINED
ROOF ACCESSORIES	(MATCH ROOF)
SIGNAGE/LETTERS	COLOR TO BE DETERMINED
LIGHT FIXTURES	FINISH TO MATCH WINDOW FRAMES

ELEVATION GENERAL NOTES

- SEE STRUCTURAL DRAWINGS FOR ALL OPENING PROTECTIVE AND CLADDING DESIGN PRESSURES.
- REFER TO FLOOR PLAN DRAWINGS FOR ADDITIONAL DIMENSIONS.
- CONTRACTOR TO COORDINATE WITH SHEET SERIES "200 SERIES" FLOOR PLANS, "900 SERIES" FINISH PLANS AND "LS" LIFE SAFETY PLAN FOR ALL WALL TYPES, PARTITION CONSTRUCTION AND OPENING PROTECTION RATINGS.
- ALL EXTERIOR OPENINGS ARE TO BE PROTECTED WITH HURRICANE IMPACT RESISTANT TESTED/NOA ASSEMBLIES MEETING DESIGN PRESSURES INDICATED IN STRUCTURAL DRAWINGS.
- CONTRACTOR TO COORDINATE ALL AREAS AND MATERIALS WITH SPECIAL CONSIDERATION FOR ITEMS WHICH ALIGN AND COORDINATE WITH FINISH MATERIALS (AS APPLICABLE). ALL CONFLICTS SHALL BE NOTICED TO ARCHITECT OR RECORD UPON DISCOVERY, WITH OPTION FOR RESOLUTION AS PRESENTED BY CONTRACTOR.
- EXTERIOR ALUMINUM STOREFRONT SYSTEMS ARE DESIGNED TO BE SET WITHIN ALUMINUM CLAD STRUCTURAL STEEL FRAME (AS APPROPRIATE). ALL EXPOSED STEEL AT THESE LOCATIONS ARE TO BE COVERED WITH ALUMINUM (WITH FINISH TO MATCH WINDOW FRAME MATERIAL) AND FLASHED SO AS TO PREVENT THE INTRUSION OF AIR OR WATER.
- ALL EXTERIOR AND INTERIOR LIGHTING, EXIT SIGNS AND FIXTURES SHALL HAVE CONCEALED CONDUIT AND HOUSINGS.
- ALL EXTERIOR "TILT-CONCRETE PANELS ARE TO BE SEALED AT BOTH SIDES WITH FULL CONTINUOUS BACKER ROD AND SEALANT. PROVIDE WEEPS AT EACH LOCATION IN ACCORDANCE WITH MANUFACTURER'S RECOMMENDATIONS.
- LOCATE EXPANSION/CONTROL JOINTS PER DRAWINGS PROVIDED AND INDUSTRY STANDARD RECOMMENDATIONS. SEAL ALL JOINTS WITH PROPER BACKING MATERIAL AND POLYURETHANE SEALANT OR PREFORMED FOAM AND RUBBER EXPANSION JOINT CLOSURE. JOINT CLOSURE/SEALANT SHALL MATCH THE COLOR OF THE MASONRY.
- ALL MASONRY TO CREATE A UNIFORM APPEARANCE WHEN INSTALLED.
- ALL THROUGH WALL FLASHING SHALL BE INSTALLED IN ACCORDANCE WITH ALL APPLICABLE BIA TECHNICALS AND SMACNA REQUIREMENTS. EXTEND METAL DRIP EDGE FLASHING BEYOND THE WALL PLANE USE A 1/4" PREFORMED 45 DEGREE ANGLE TURN DOWN.
- VEENER REINFORCING SHALL BE GALVANIZED TO G90 COATING AND SUFFICIENT SIZE TO ELIMINATE DAMAGE TO VENEER LAYER FROM WIND AND OTHER LIVE AND DEAD LOADS IMPOSED.

PANEL JOINTS

1. ALL PANEL/MATERIAL JOINTS, SCORE LINES AND REVEALS LISTED BELOW ARE INTENDED TO DEMONSTRATE THE BASIS OF DESIGN AND BASE EXTERIOR ARCHITECTURAL PLAN AND USER/OWNER APPROVALS. ALL SCORE LINES ARE TO BE SCORE LINE TYPE "B" UNLESS OTHERWISE NOTED.

SCORE LINE TYPE	BASIS OF DESIGN
A	1-1/2" PANEL JOINT
B	1-1/2" PANEL RECESS
C	2" PANEL RECESS
D	6" PANEL RECESS

CHECKED BY: LR	DRAWN BY: CV
-------------------	-----------------

CONSULTANT INFO:




NEW ELEMENTARY SCHOOL (K-5)

VENETIAN PARC WEST

SOUTHWEST 157th AVENUE and 174th STREET
MIAMI, FL. 33187

MDCPS PROJECT No. 01892600

KEY PLAN

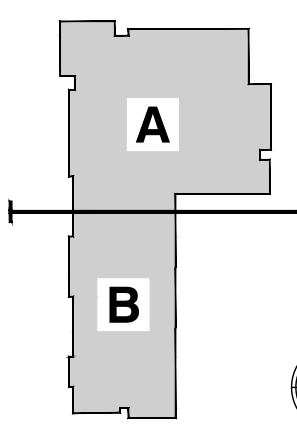

CONSULTANT INFO:

RODRIGUEZ ARCHITECTS INCORPORATED
2121 PONCE DE LEON BLVD. STE 1010
CORAL GABLES, FL. 33134
TEL: (305) 448-3373
FAX: (305) 448-3374
A A C - 0 0 1 9 3 3

RODRIGUEZ ARCHITECTS INCORPORATED
2121 PONCE DE LEON BLVD. STE 1010
CORAL GABLES, FL. 33134
TEL: (305) 448-3373
FAX: (305) 448-3374
A A C - 0 0 1 9 3 3

RAI

REVISIONS:

DRAWING TITLE:


BUILDING ELEVATIONS

SCALE AS NOTED

ISSUE DATE: 12/16/19


PROJECT NO: 1906

SHEET: A-502

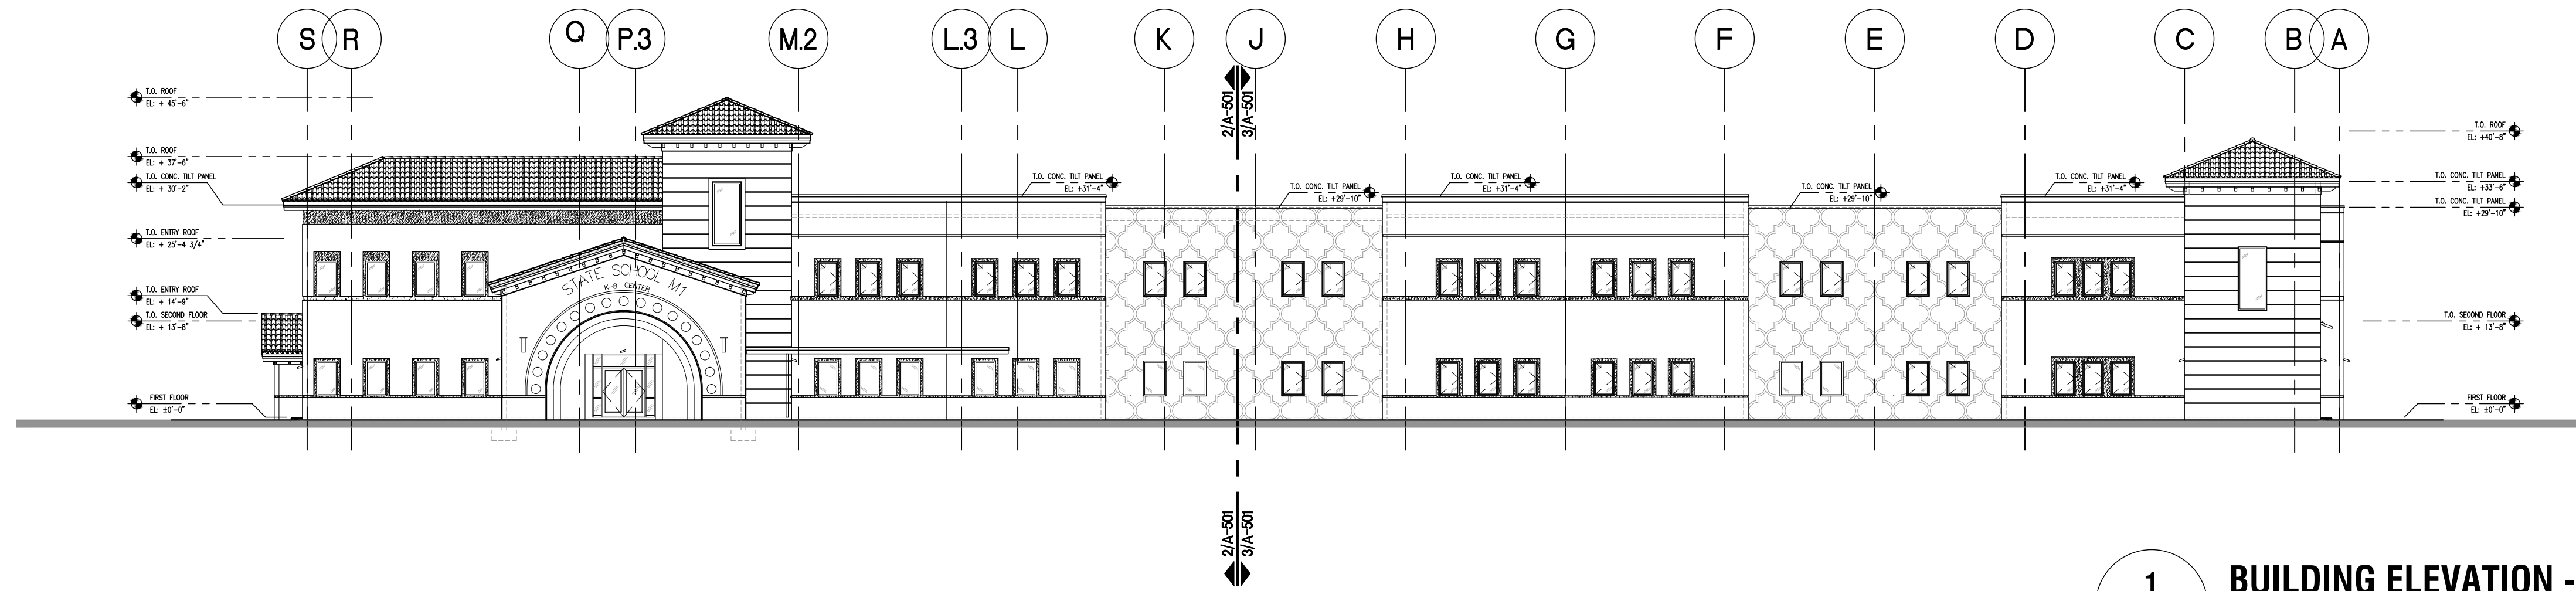


1 BUILDING ELEVATION - WEST

A-503 Scale: 1/16" = 1'-0"

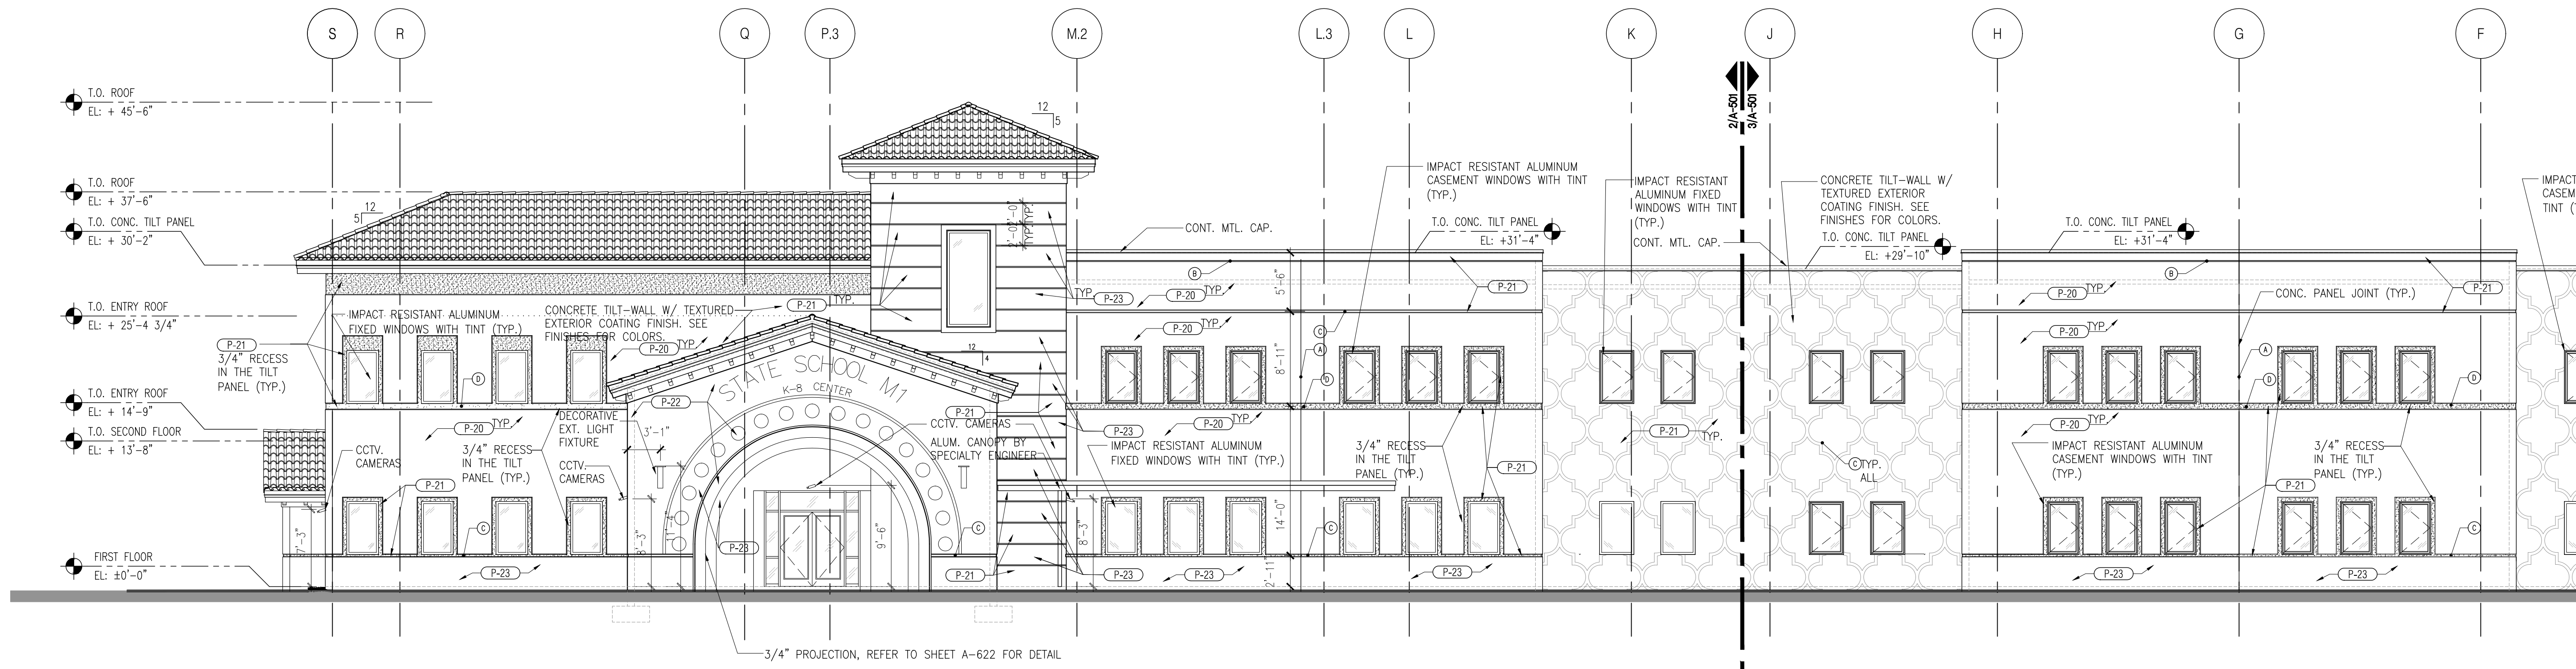

2 BUILDING ELEVATION - WEST


A-503 Scale: 1/8" = 1'-0"

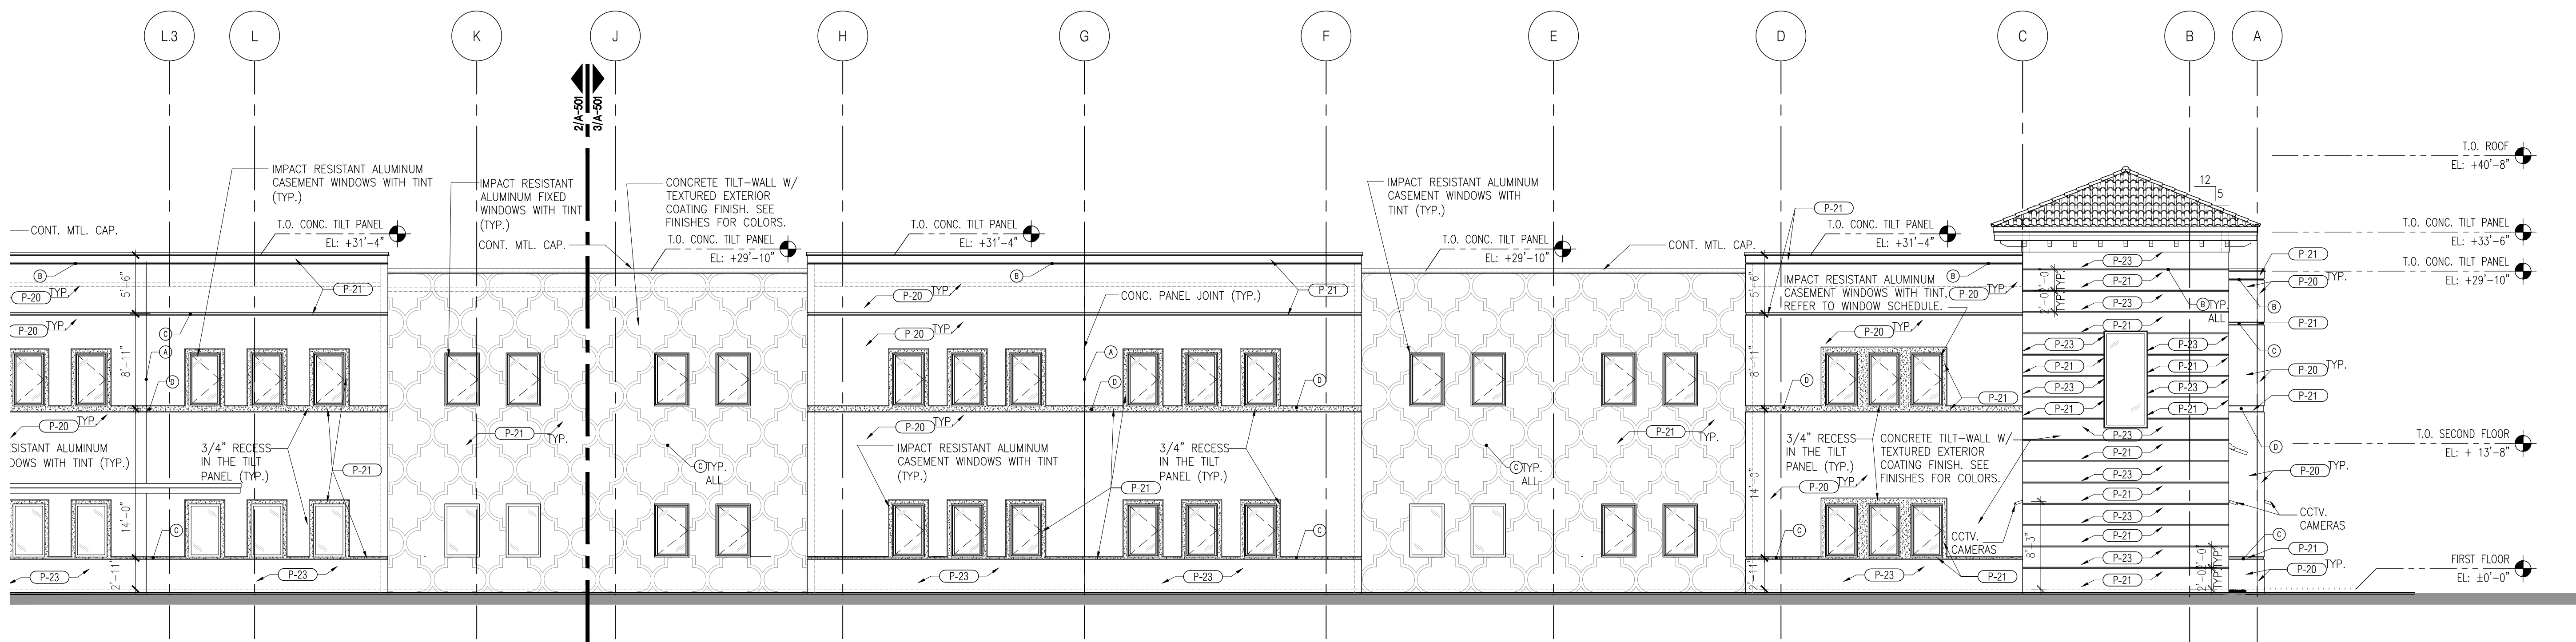

3 BUILDING ELEVATION - WEST

A-503 Scale: 1/8" = 1'-0"

ELEVATION LEGEND

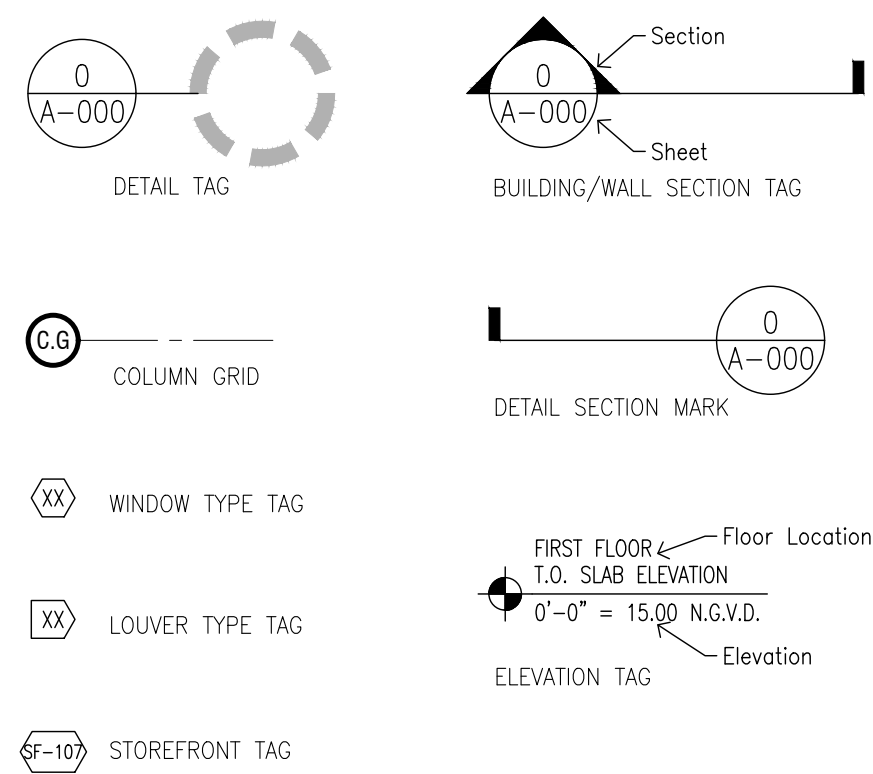

EXTERIOR FINISH BASIS OF DESIGN

- ALL FINISHES LISTED BELOW ARE INTENDED TO DEMONSTRATE THE BASIS OF DESIGN AND APPROVALS PER PROVIDED DOWNTOWN DORAL STANDARDS AND USER/OWNER APPROVALS.

MATERIAL	BASIS OF DESIGN
P-20 PAINT (FIELD)	2167-60 SWEET SALMON BENJAMIN MOORE
P-21 ACCENT PAINT	2167-40 TOFFEE ORANGE BENJAMIN MOORE
P-22 ACCENT PAINT	2162-40 PEANUT SHELL BENJAMIN MOORE
TRIM1	WINDOWS/DOORS/DETAIL COLOR TO BE DETERMINED
TRIM2	ROOF FASCIA/SOFFIT/DENTILS COLOR TO BE DETERMINED
WINDOW/DOOR FRAME AND ACCESSORIES	FINISH TO BE DETERMINED
EXTERIOR GLAZING	TINTED - LOW-E COATING FINISH TO BE DETERMINED
S-TILE ROOF/SLOPED TILE	CLAY/PAINT FINISH COLOR TO BE DETERMINED
ROOF ACCESSORIES	(MATCH ROOF)
SIGNAGE/LETTERS	COLOR TO BE DETERMINED
LIGHT FIXTURES	FINISH TO MATCH WINDOW FRAMES

ELEVATION GENERAL NOTES

- SEE STRUCTURAL DRAWINGS FOR ALL OPENING PROTECTIVE AND CLADDING DESIGN PRESSURES.
- REFER TO FLOOR PLAN DRAWINGS FOR ADDITIONAL DIMENSIONS.
- CONTRACTOR TO COORDINATE WITH SHEET SERIES "200 SERIES" FLOOR PLANS, "900 SERIES" FINISH PLANS AND "LS" LIFE SAFETY PLAN FOR ALL WALL TYPES, PARTITION CONSTRUCTION AND OPENING PROTECTION RATINGS.
- ALL EXTERIOR OPENINGS ARE TO BE PROTECTED WITH HURRICANE IMPACT RESISTANT TESTED/NOA ASSEMBLIES MEETING DESIGN PRESSURES INDICATED IN STRUCTURAL DRAWINGS.
- CONTRACTOR TO COORDINATE ALL AREAS AND MATERIALS WITH SPECIAL CONSIDERATION FOR ITEMS WHICH ALIGN AND COURSE WITH FINISH MATERIALS (AS APPLICABLE). ALL CONFLICTS SHALL BE NOTICED TO ARCHITECT OR RECORD UPON DISCOVERY, WITH OPTION FOR RESOLUTION AS PRESENTED BY CONTRACTOR.
- EXTERIOR ALUMINUM STOREFRONT SYSTEMS ARE DESIGNED TO BE SET WITHIN ALUMINUM CLAD STRUCTURAL STEEL FRAME (AS APPROPRIATE). ALL EXPOSED STEEL AT THESE LOCATIONS ARE TO BE COVERED WITH ALUMINUM (WITH FINISH TO MATCH WINDOW FRAME MATERIAL) AND FLASHED SO AS TO PREVENT THE INTRUSION OF AIR OR WATER.
- ALL EXTERIOR AND INTERIOR LIGHTING, EXIT SIGNS AND FIXTURES SHALL HAVE CONCEALED CONDUIT AND HOUSINGS.
- ALL EXTERIOR "TILT-CONCRETE PANELS ARE TO BE SEALED AT BOTH SIDES WITH FULL CONTINUOUS BACKER ROD AND SEALANT. PROVIDE WEEPS AT EACH LOCATION IN ACCORDANCE WITH MANUFACTURER'S RECOMMENDATIONS.
- LOCATE EXPANSION/CONTROL JOINTS PER DRAWINGS PROVIDED AND INDUSTRY STANDARD RECOMMENDATIONS. SEAL ALL JOINTS WITH PROPER BACKING MATERIAL AND POLYURETHANE SEALANT OR PREFORMED FOAM AND RUBBER EXPANSION JOINT CLOSURE. JOINT CLOSURE/SEALANT SHALL MATCH THE COLOR OF THE MASONRY.
- ALL MASONRY TO CREATE A UNIFORM APPEARANCE WHEN INSTALLED.
- ALL THROUGH WALL FLASHING SHALL BE INSTALLED IN ACCORDANCE WITH ALL APPLICABLE BIA TECHNOTES AND SMACNA REQUIREMENTS. EXTEND METAL DRIP EDGE FLASHING BEYOND THE WALL PLANE USE A 1/4" PERFORMED 45 DEGREE ANGLE TURN DOWN.
- VENIER REINFORCING SHALL BE GALVANIZED TO G90 COATING AND SUFFICIENT SIZE TO ELIMINATE DAMAGE TO VENIER LAYER FROM WIND AND OTHER LIVE AND DEAD LOADS IMPOSED.


PANEL JOINTS

- ALL PANEL/MATERIAL JOINTS, SCORE LINES AND REVEALS LISTED BELOW ARE INTENDED TO DEMONSTRATE THE BASIS OF DESIGN AND BASE EXTERIOR ARCHITECTURAL PLAN AND USER/OWNER APPROVALS. ALL SCORE LINES ARE TO BE SCORE LINE TYPE "B" UNLESS OTHERWISE NOTED.

SCORE LINE TYPE	BASIS OF DESIGN
A	1-1/2" PANEL JOINT
B	1-1/2" PANEL RECESS
C	2" PANEL RECESS
D	6" PANEL RECESS


CHECKED BY: LR. DRAWN BY: CV.

CONSULTANT INFO:

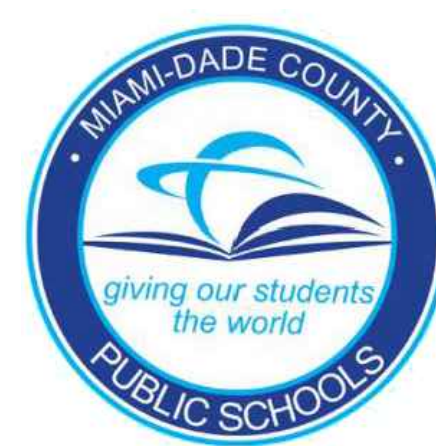


NEW ELEMENTARY SCHOOL (K-5)
VENETIAN PARC WEST
SOUTHWEST 157th AVENUE and 174th STREET
MIAMI, FL. 33187
MDCPS PROJECT No. 01892600

KEY PLAN

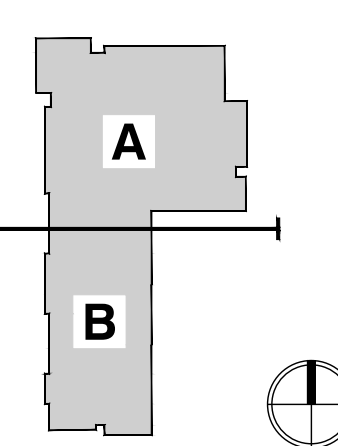

CONSULTANT INFO:

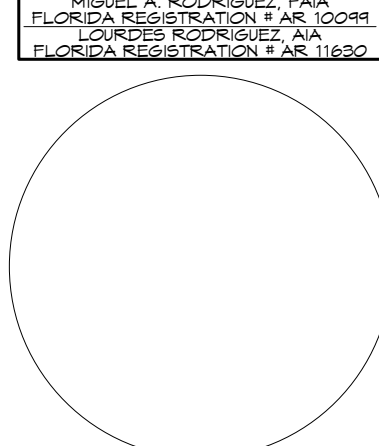

RODRIGUEZ ARCHITECTS INCORPORATED
2121 PONCE DE LEON BLVD. STE 1010
CORAL GABLES, FL. 33134
TEL: (305) 448-3373
FAX: (305) 448-3374
AAC - 001933

RAI

REVISIONS:


DRAWING TITLE:

BUILDING ELEVATIONS


SCALE AS NOTED

ISSUE DATE: 12/16/14 PROJECT NO: 1906

SHEET: A-503

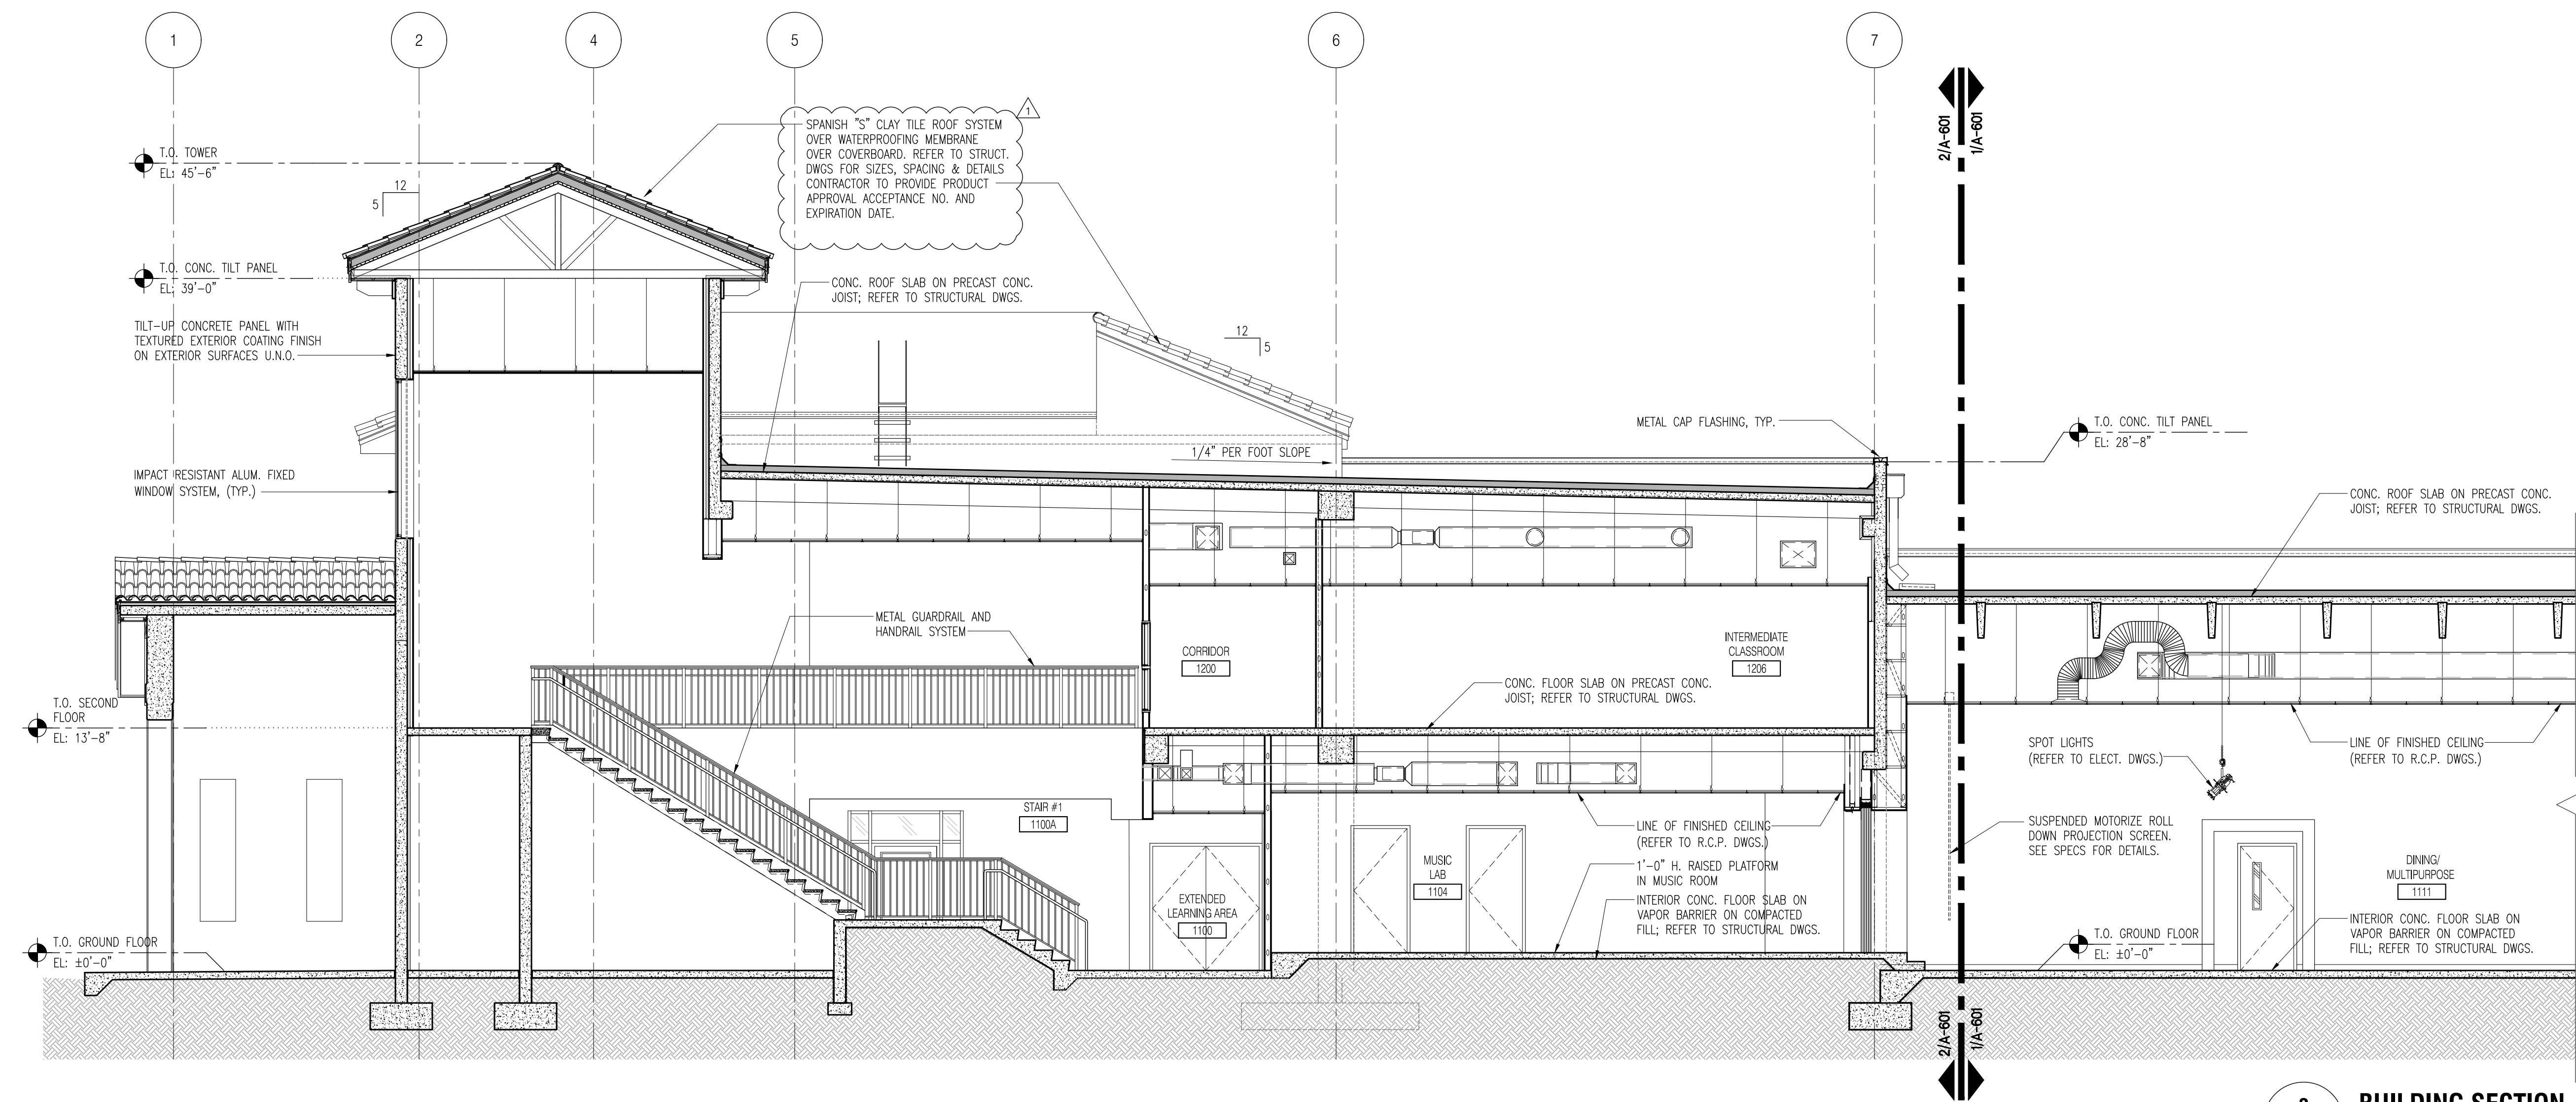

2 BUILDING SECTION
A-601 Scale: 3/16" = 1'-0"

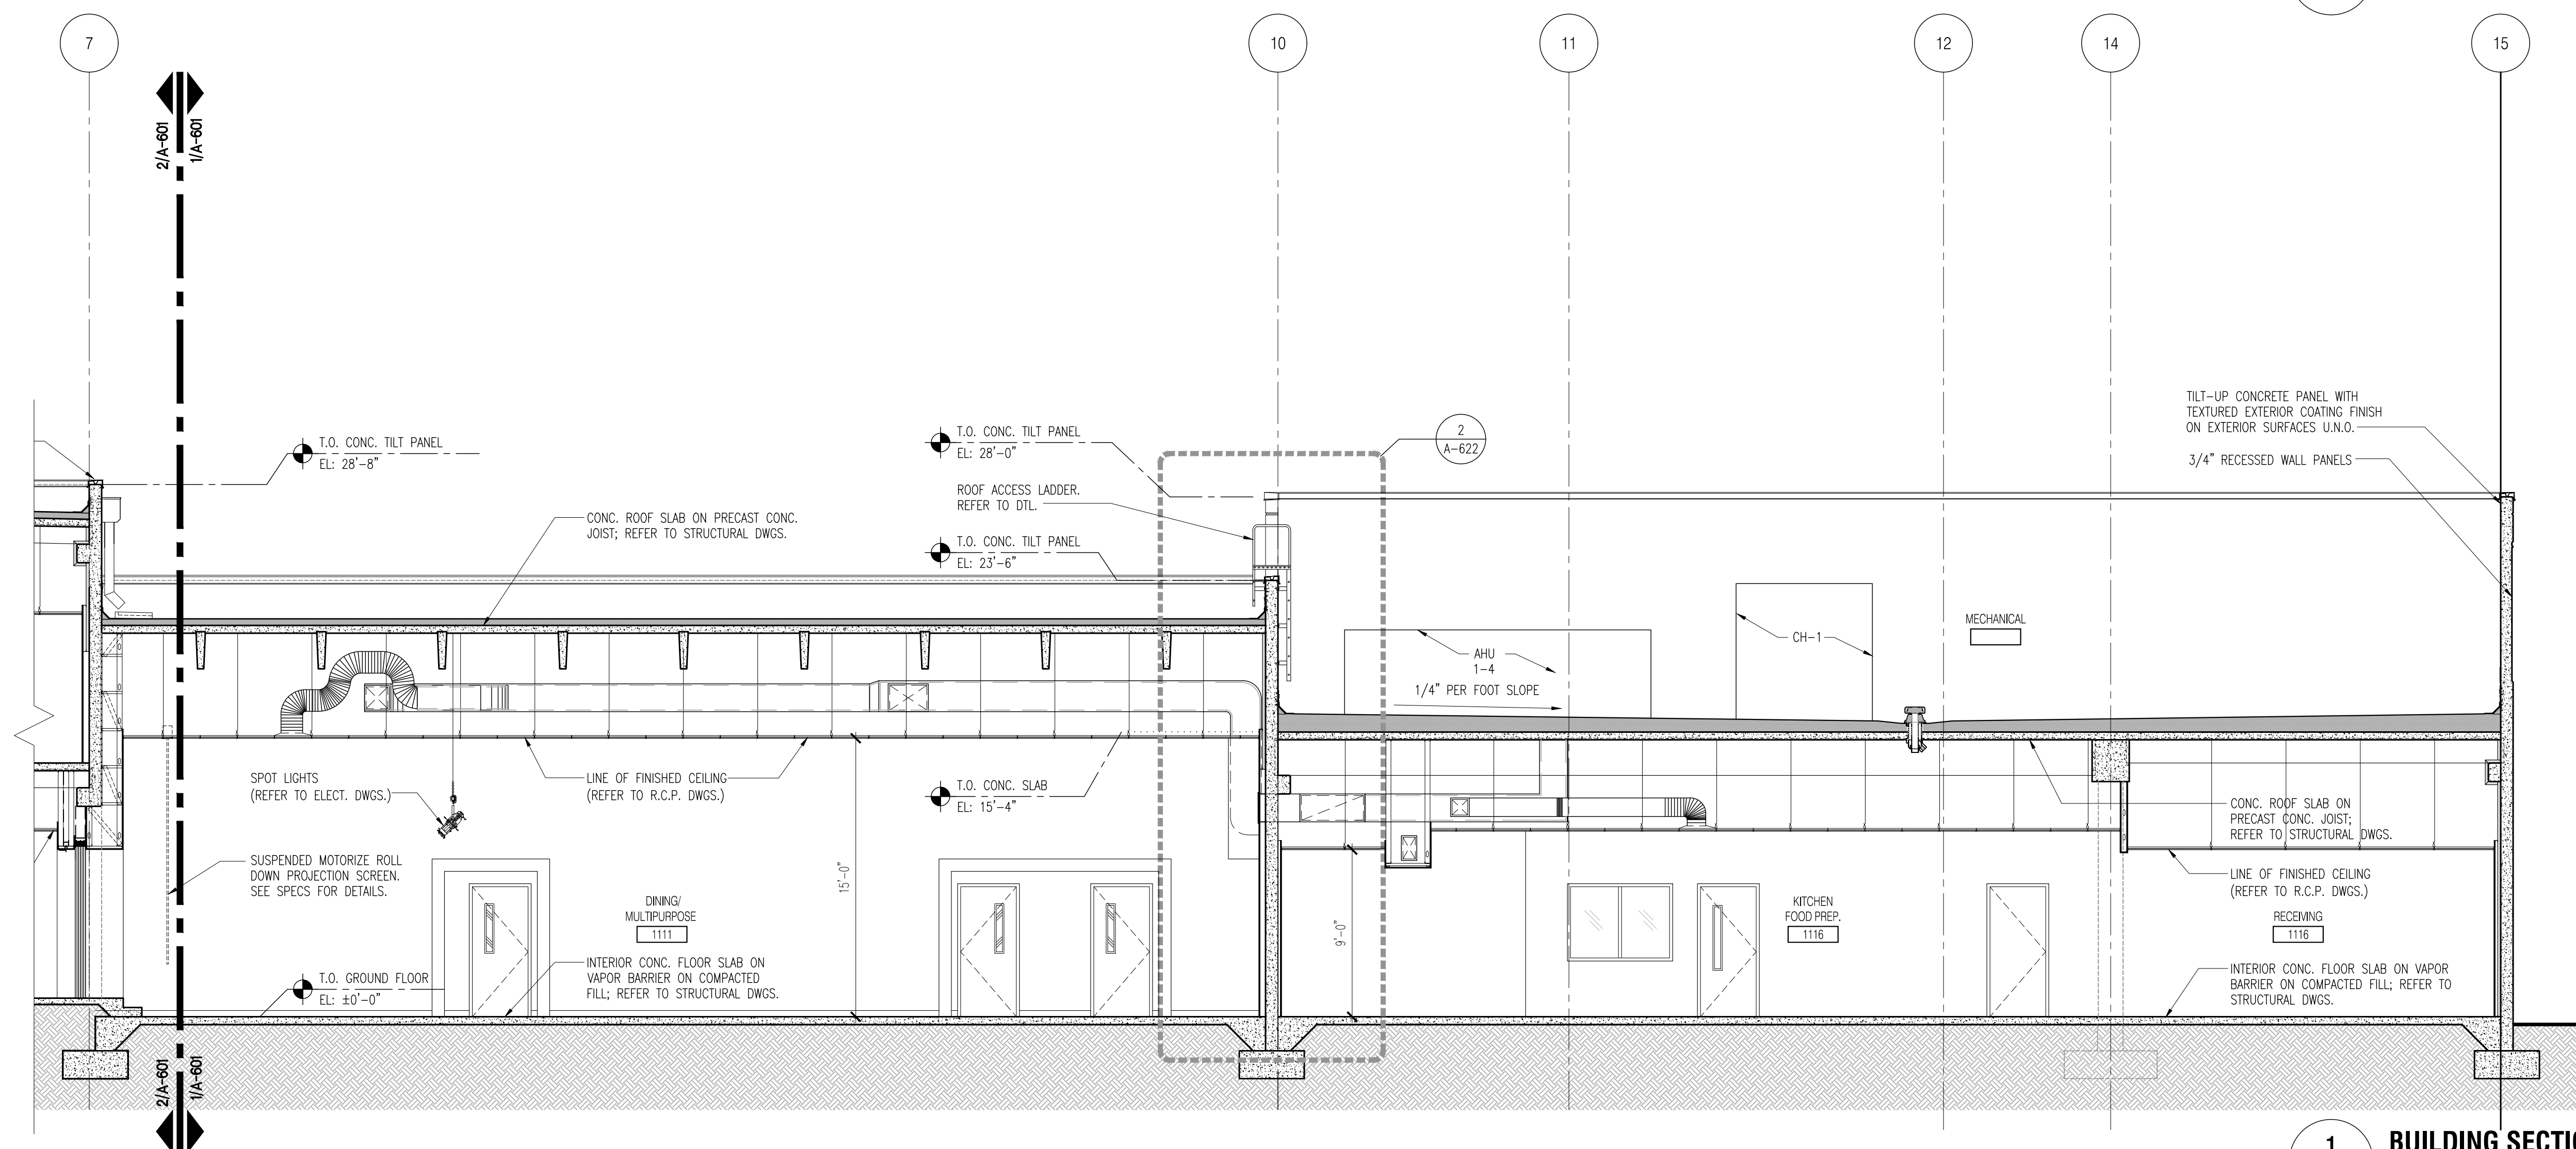

1 BUILDING SECTION
A-601 Scale: 3/16" = 1'-0"


CHECKED BY: LR	DRAWN BY: CV
-------------------	-----------------

CONSULTANT INFO:



NEW ELEMENTARY SCHOOL (K-5)
VENETIAN PARC WEST
SOUTHWEST 157th AVENUE and 174th STREET
MIAMI, FL. 33187
MDCPS PROJECT No. 01892600

KEY PLAN

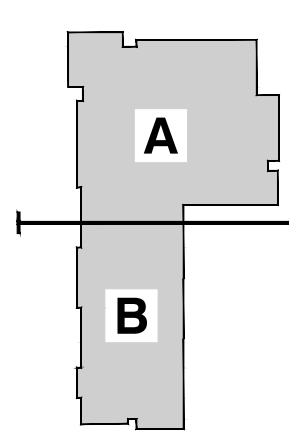

CONSULTANT INFO:

DESIGN & CONSTRUCTION
2121 PONCE DE LEON BLVD. STE. 1010
CORAL GABLES, FL. 33134
TEL: (305) 448-3373
FAX: (305) 448-3374

RODRIGUEZ ARCHITECTS INCORPORATED
2121 PONCE DE LEON BLVD. STE. 1010
CORAL GABLES, FL. 33134
TEL: (305) 448-3373
FAX: (305) 448-3374
A A C — 0 0 1 9 3 3

RAI

REVISIONS:

02/14/2020 BUILDING DEPARTMENT COMMENTS


DRAWING TITLE:

BUILDING SECTIONS


SCALE AS NOTED

ISSUE DATE 12/16/19	PROJECT NO. 1906
------------------------	---------------------


SHEET: **A-601**

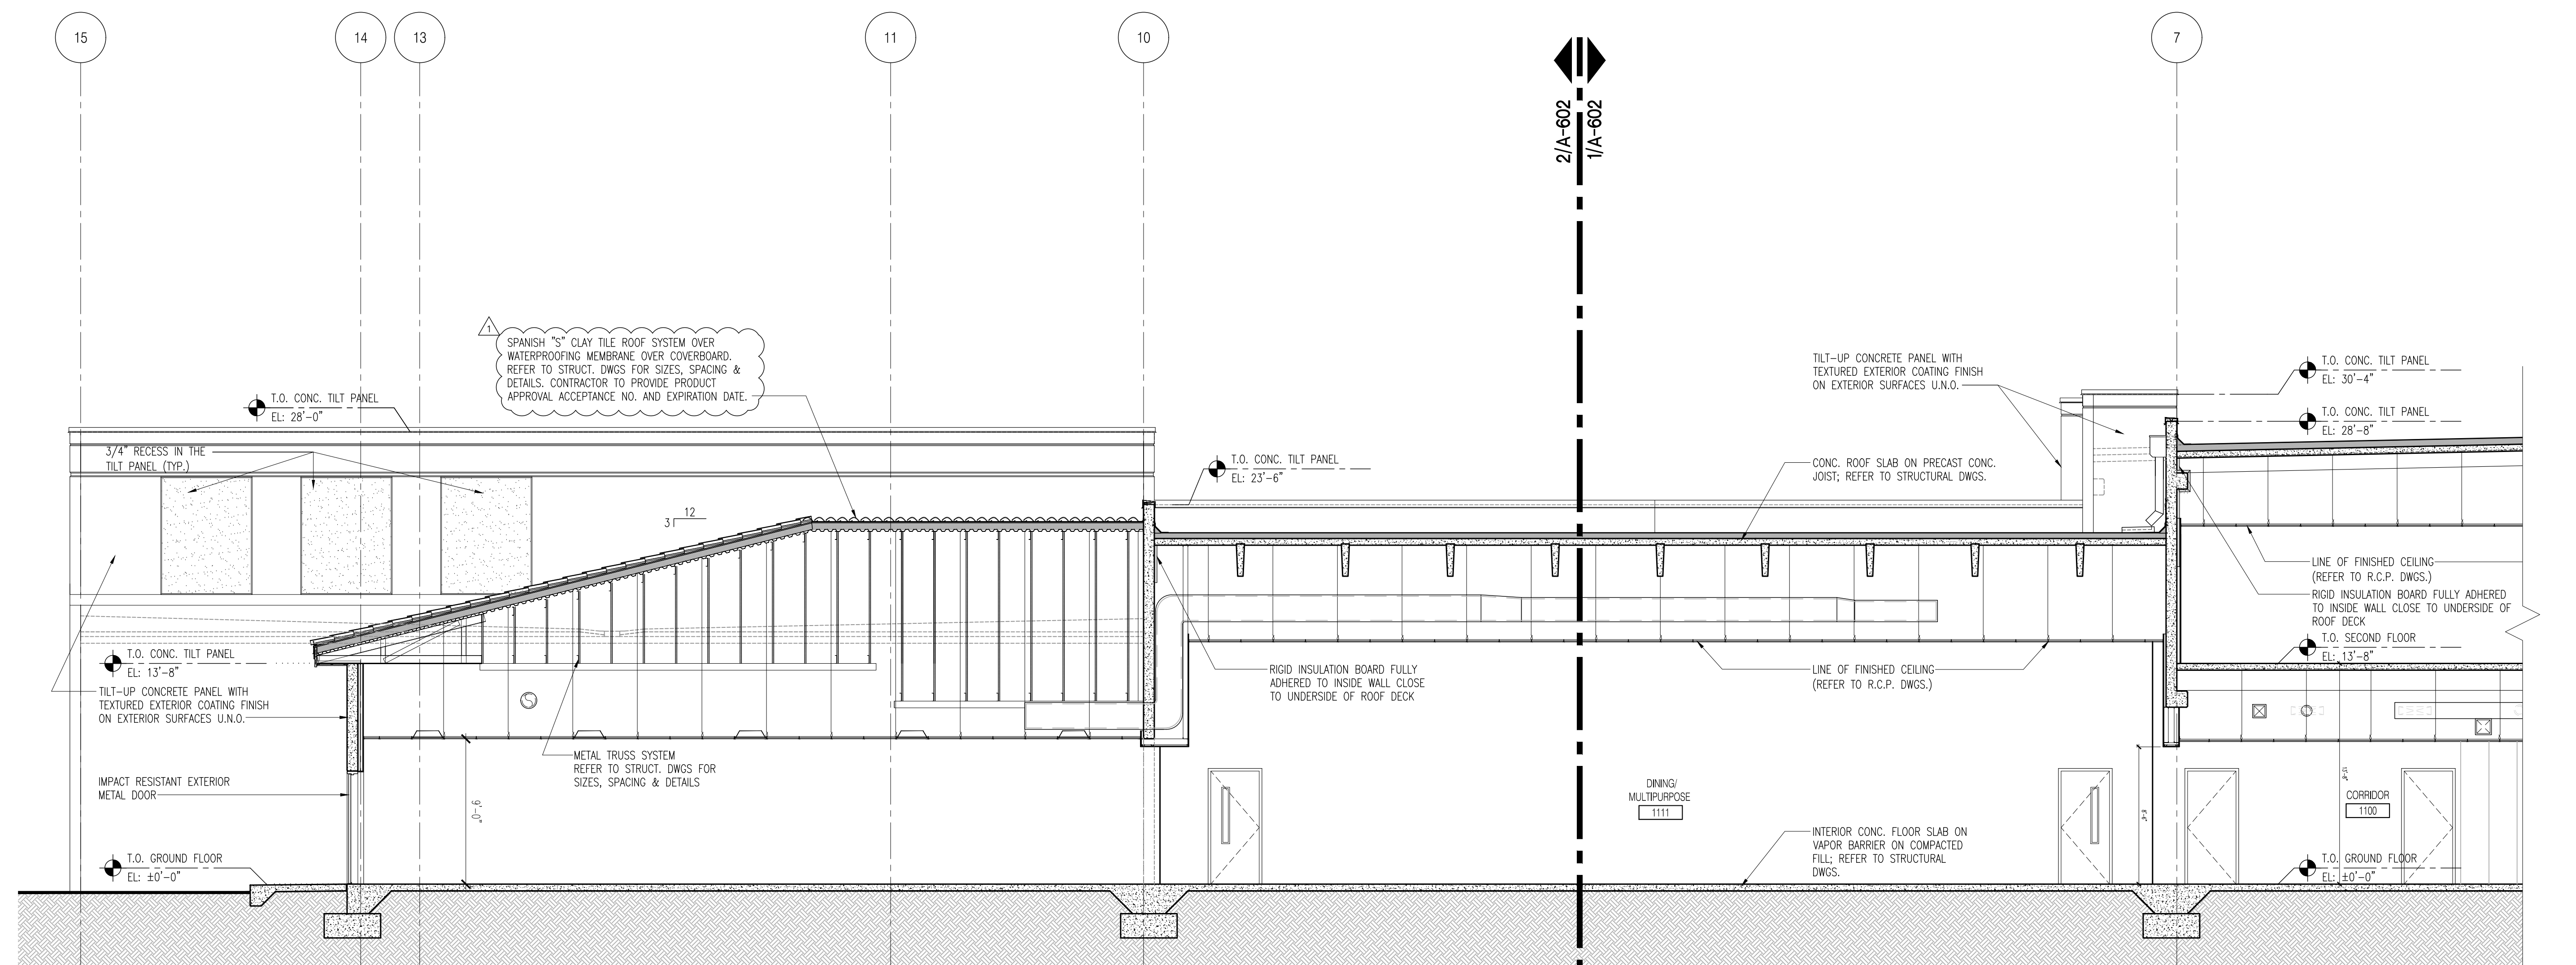

2 BUILDING SECTION
A-602 Scale: 3/16" = 1'-0"

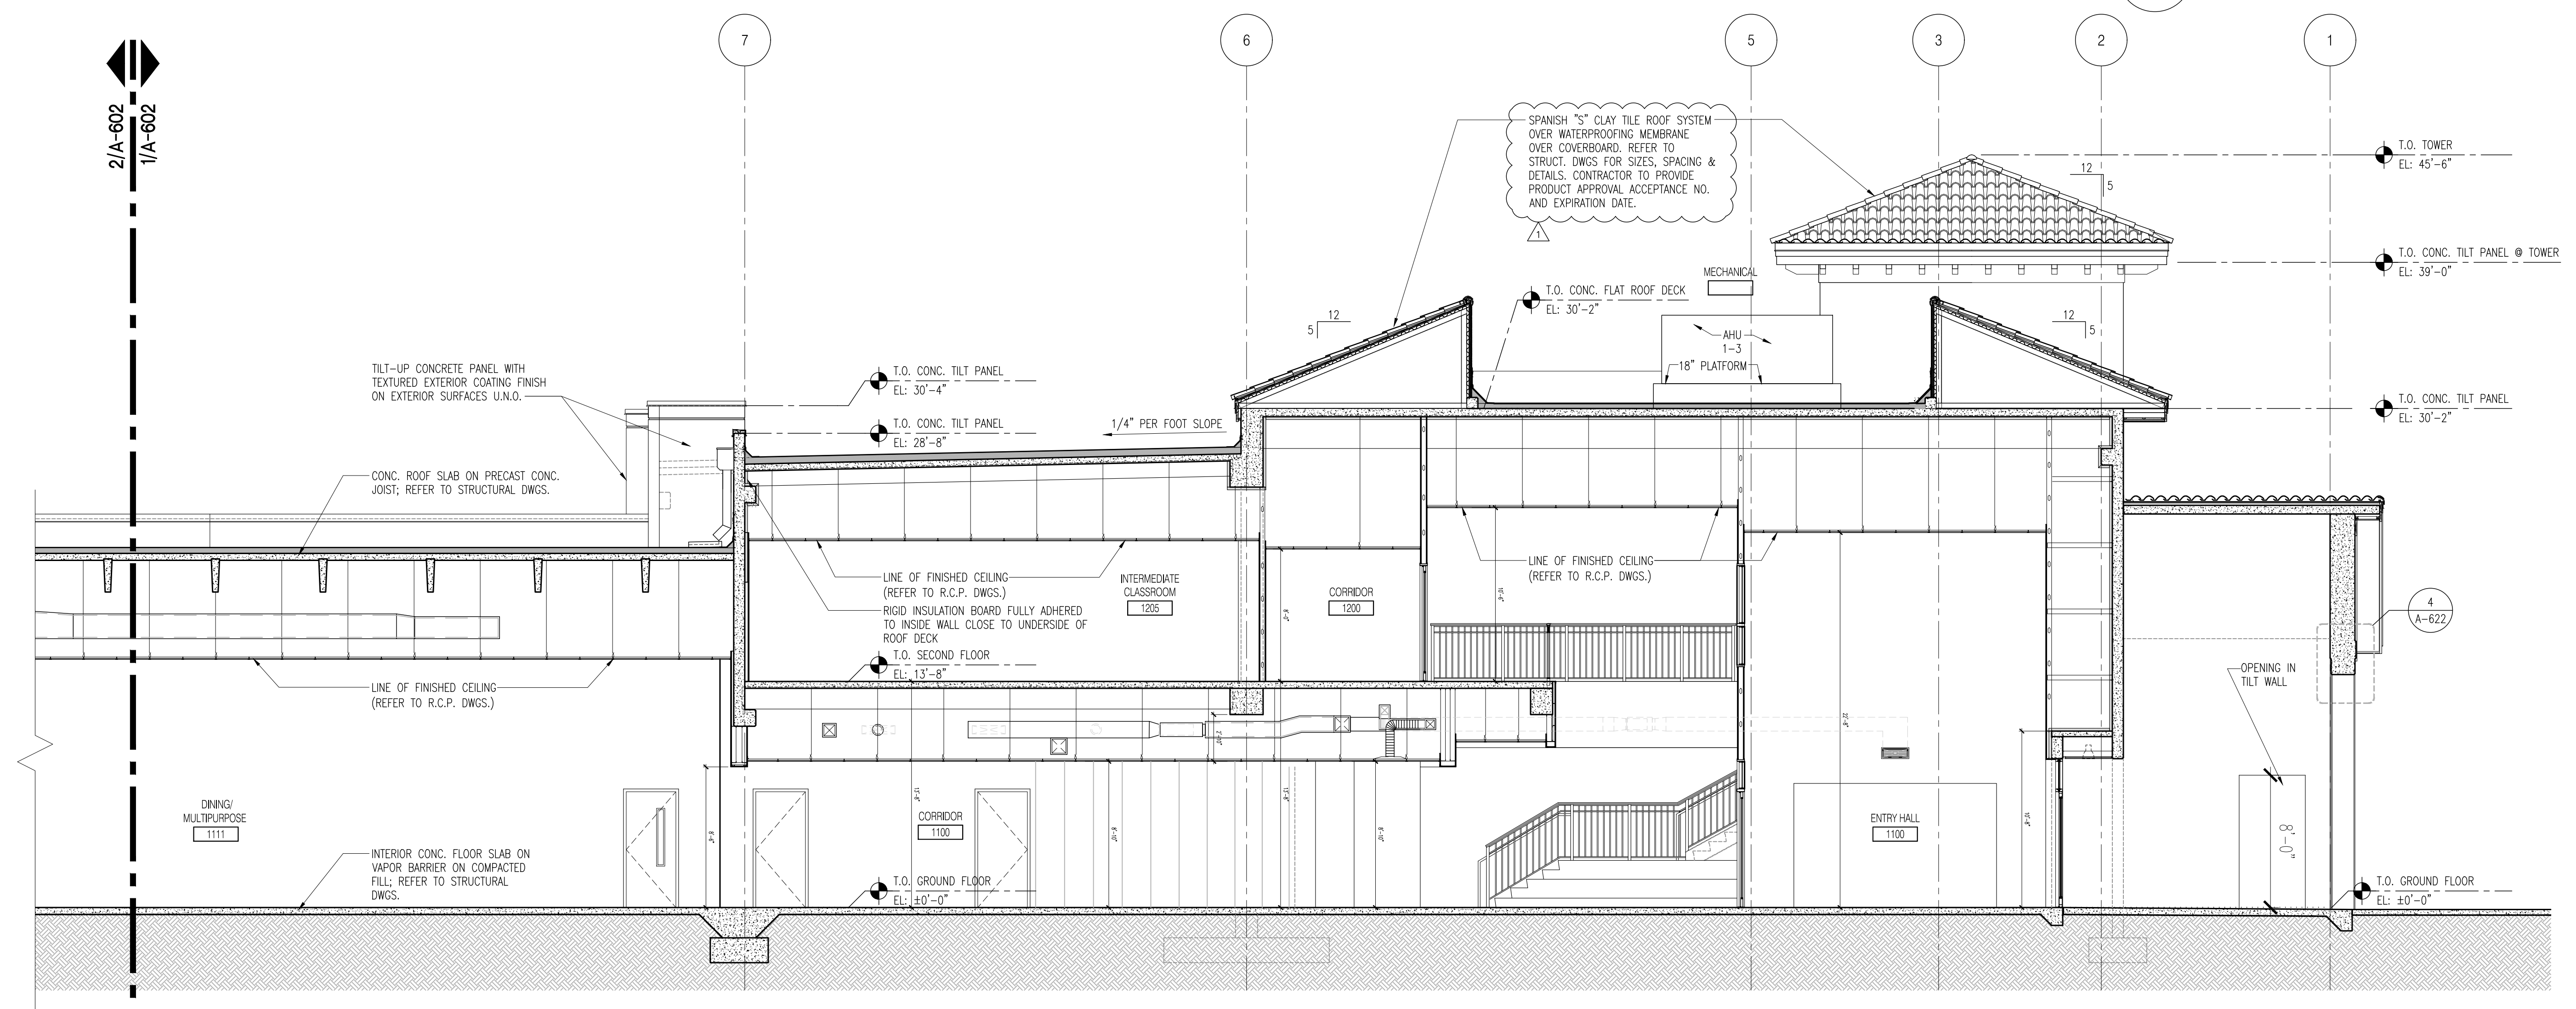

1 BUILDING SECTION
A-602 Scale: 3/16" = 1'-0"

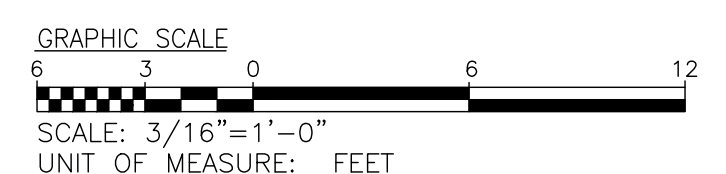


CHECKED BY: LR	DRAWN BY: CV
-------------------	-----------------

CONSULTANT INFO:



NEW ELEMENTARY SCHOOL (K-5)
VENETIAN PARC WEST
SOUTHWEST 157th AVENUE and 174th STREET
MIAMI, FL. 33187
MDCPS PROJECT No. 01892600

KEY PLAN

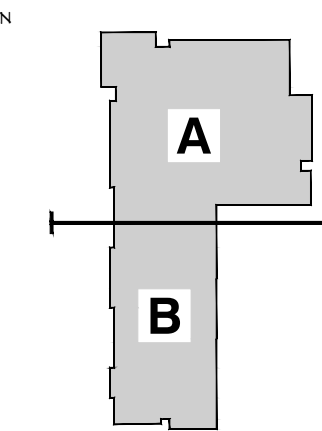

CONSULTANT INFO:

RODRIGUEZ ARCHITECTS
INCORPORATED
2121 PONCE DE LEON BLVD. STE 1010
CORAL GABLES, FL. 33134
TEL: (305) 448-3373
FAX: (305) 448-3374
A A C - 0 0 1 9 3 3

**RODRIGUEZ
ARCHITECTS
INCORPORATED**
2121 PONCE DE LEON BLVD. STE 1010
CORAL GABLES, FL. 33134
TEL: (305) 448-3373
FAX: (305) 448-3374
A A C - 0 0 1 9 3 3




REVISIONS:


NO.	DATE	DESCRIPTION
1	02/14/2020	BUILDING DEPARTMENT COMMENTS

DRAWING TITLE:

BUILDING SECTIONS	
ISSUE DATE: 12/16/19	PROJECT NO: 1906
SHEET: A-602	

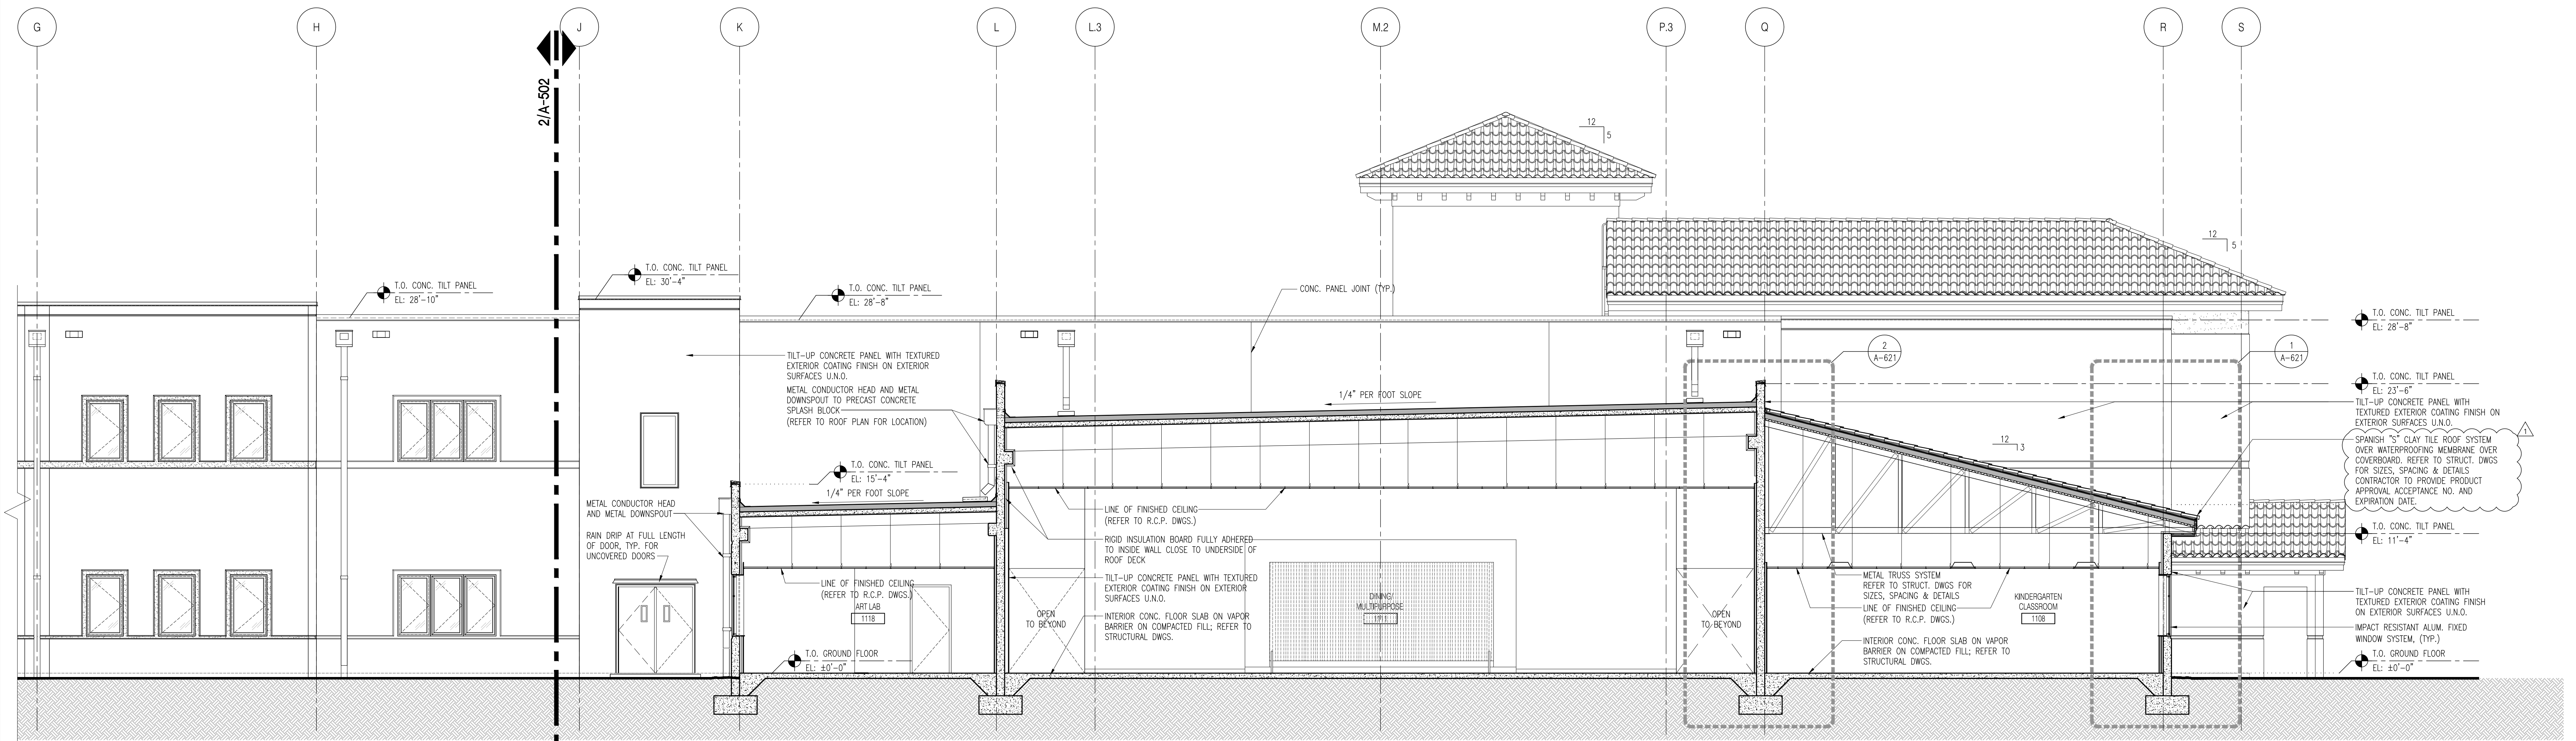


2 BUILDING SECTION
A-603 Scale: 3/16" = 1'-0"

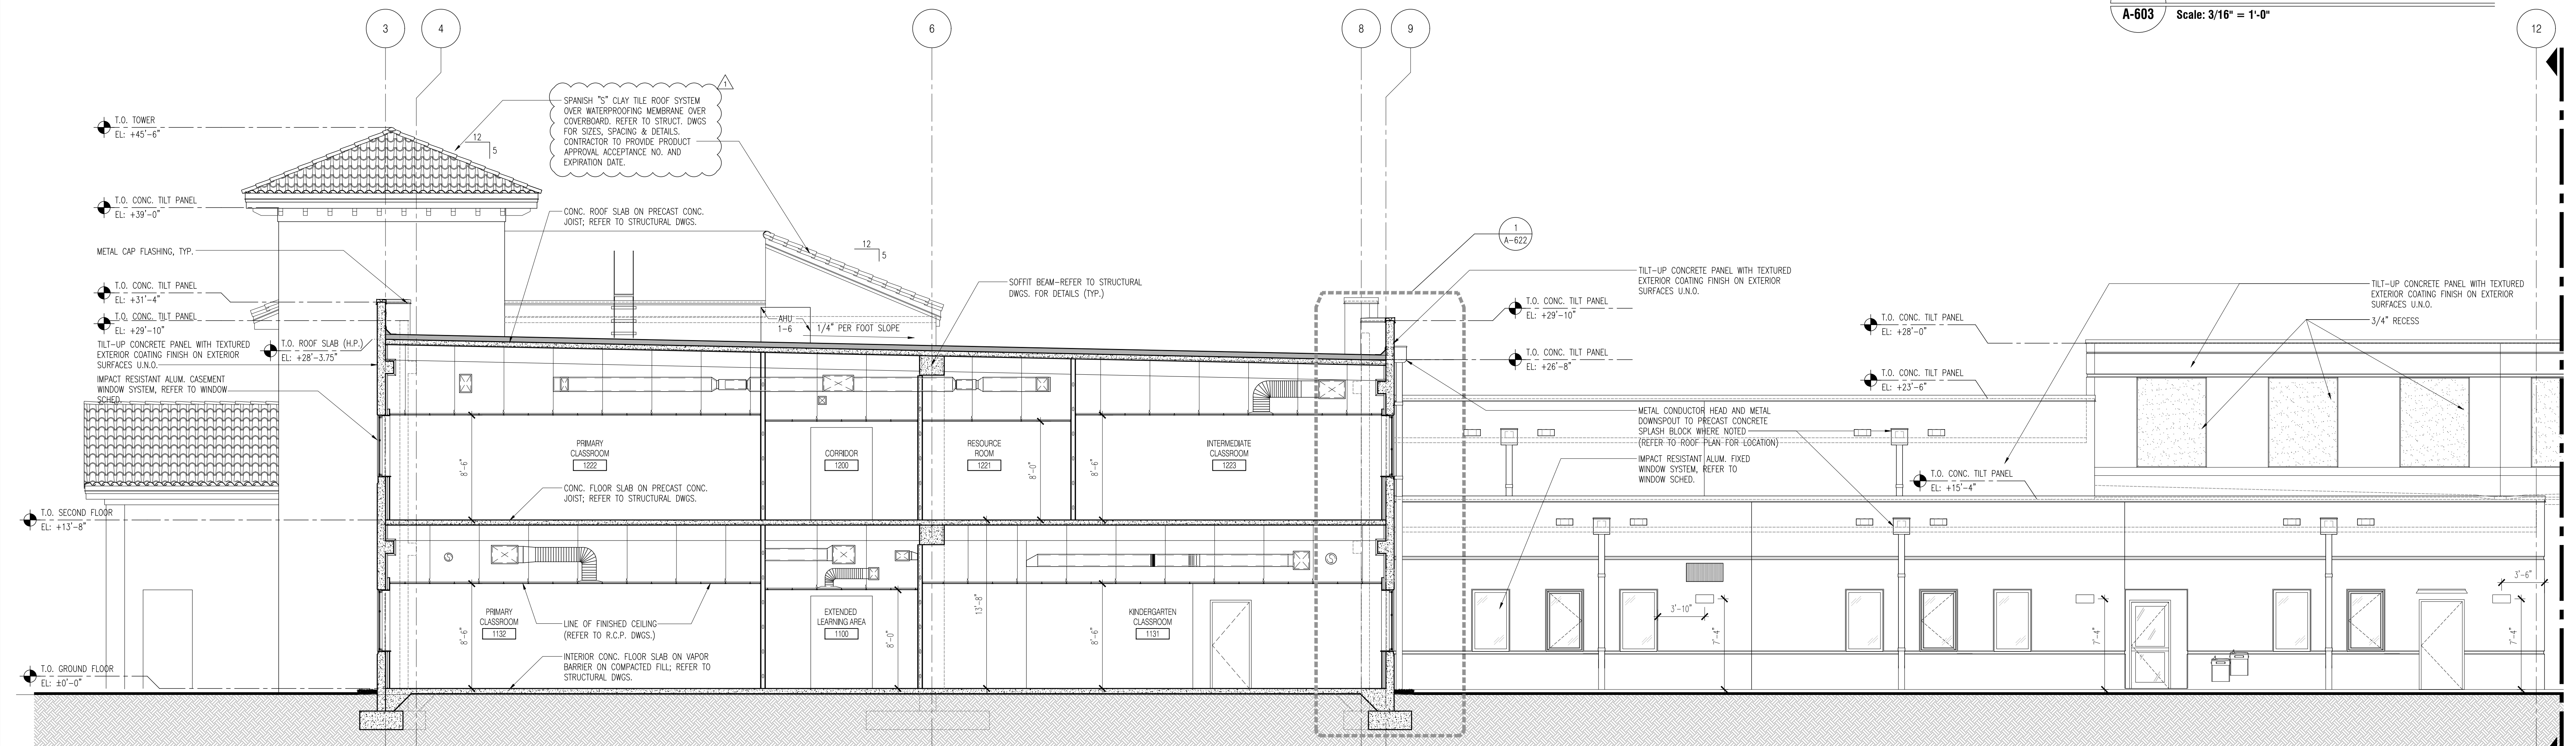

1 BUILDING SECTION
A-603 Scale: 3/16" = 1'-0"


CHECKED BY: LR	DRAWN BY: CV
-------------------	-----------------

CONSULTANT INFO:

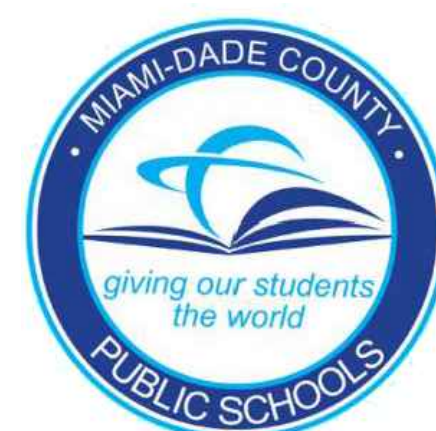

NEW ELEMENTARY SCHOOL (K-5)
VENETIAN PARC WEST
SOUTHWEST 157th AVENUE and 174th STREET
MIAMI, FL. 33187
MDCPS PROJECT No. 01892600

KEY PLAN

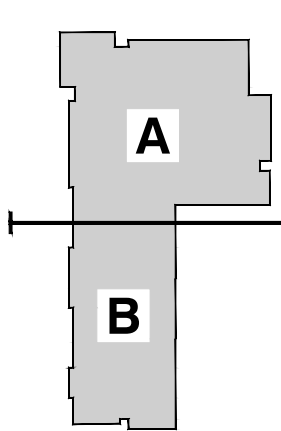

CONSULTANT INFO:

RODRIGUEZ ARCHITECTS
2121 PONCE DE LEON BLVD. STE 1010
CORAL GABLES, FL 33134
TEL: (305) 448-3373
FAX: (305) 448-3374
AAC - 001933

RODRIGUEZ ARCHITECTS INCORPORATED
2121 PONCE DE LEON BLVD. STE 1010
CORAL GABLES, FL 33134
TEL: (305) 448-3373
FAX: (305) 448-3374
AAC - 001933



REVISIONS:

02.14.2020 BUILDING DEPARTMENT COMMENTS

DRAWING TITLE:


BUILDING SECTIONS

SCALE AS NOTED


ISSUE DATE: 12.16.19

PROJECT NO: 1906

SHEET: A-603

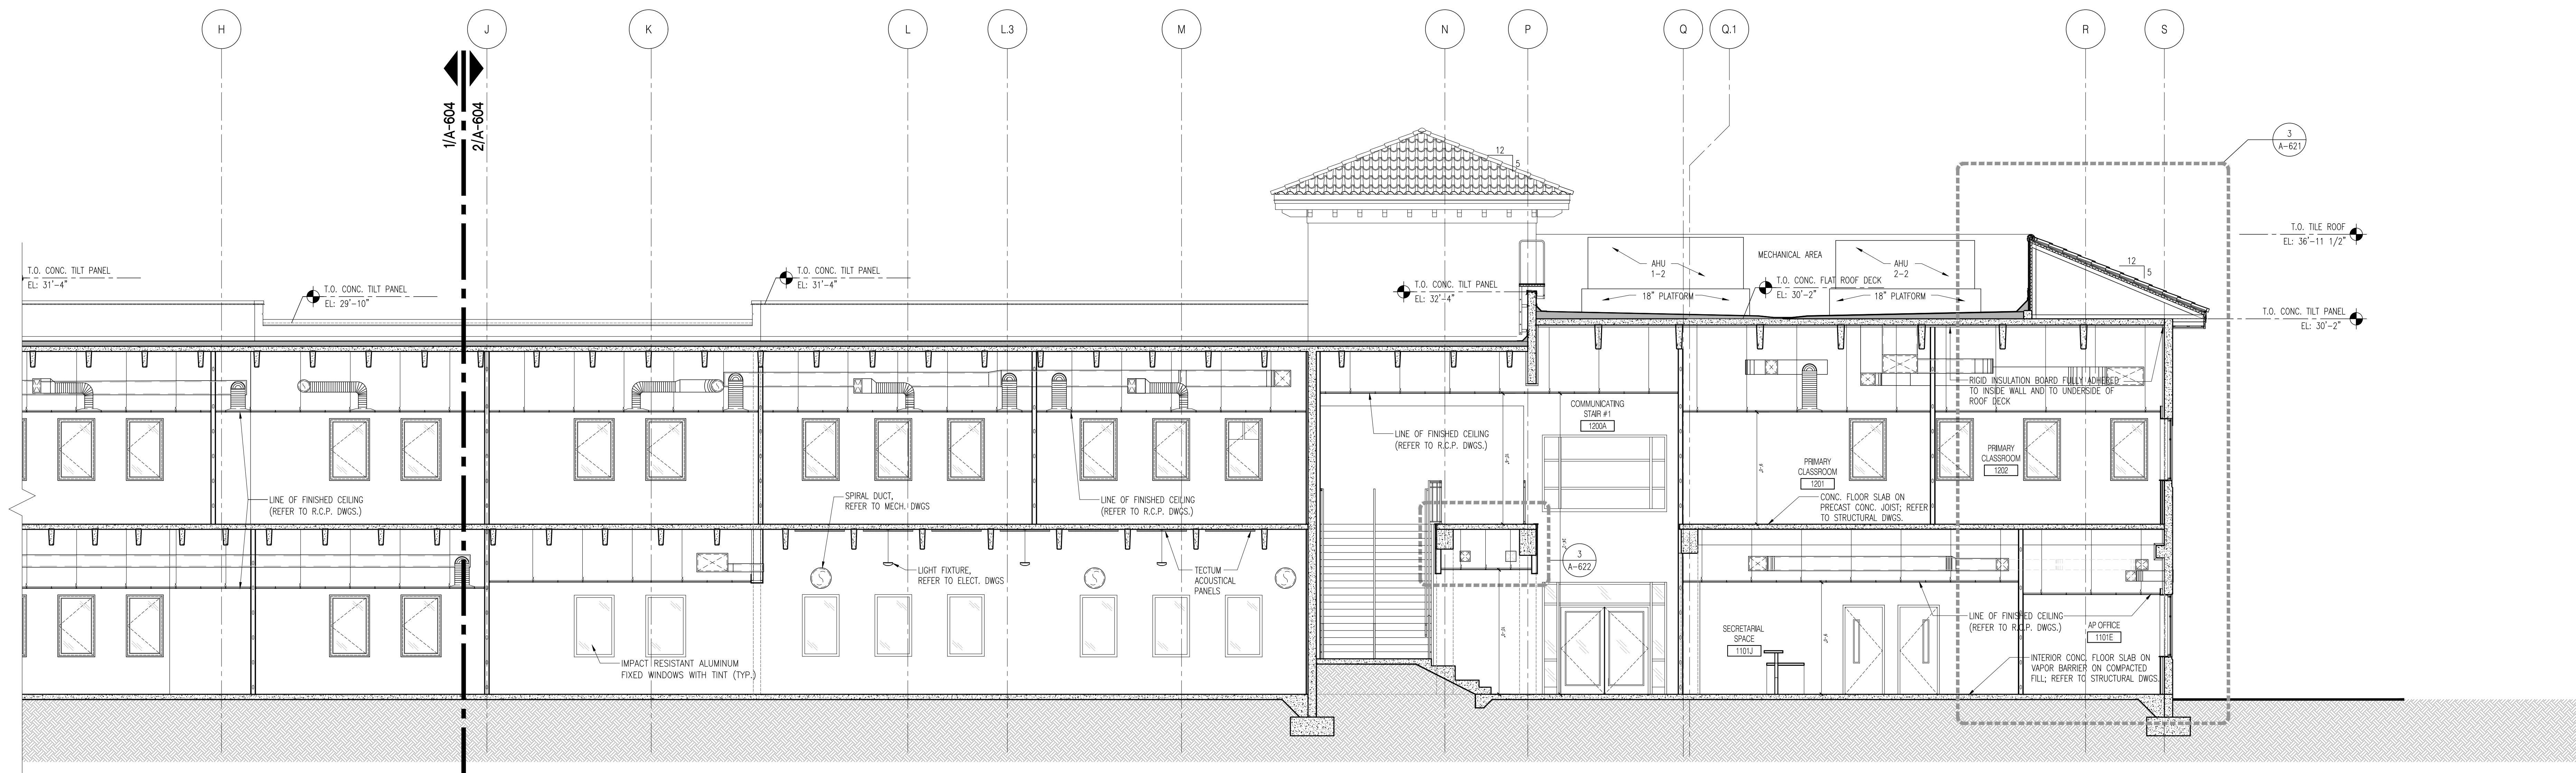


2 BUILDING SECTION
A-604 Scale: 3/16" = 1'-0"

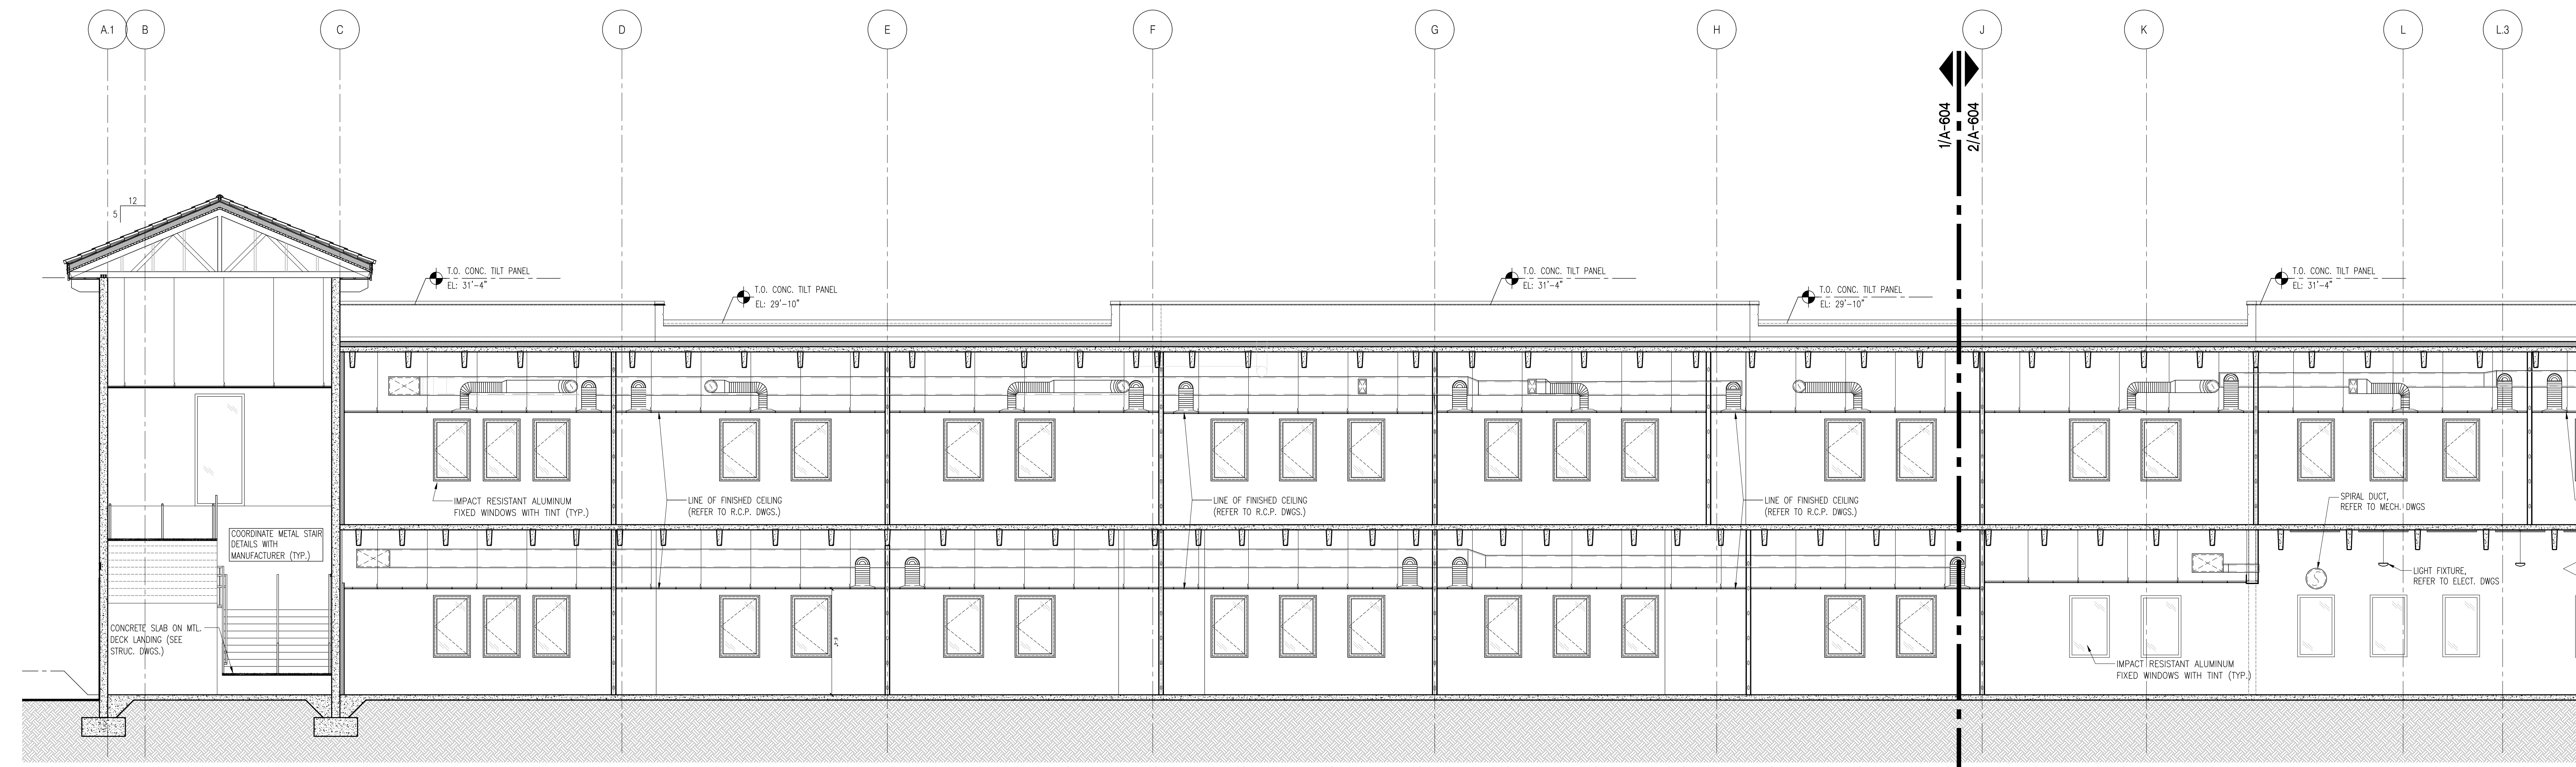


1 BUILDING SECTION
A-604 Scale: 3/16" = 1'-0"

<p>CHECKED BY: LR</p> <p>DRAWN BY: CV</p>	<p>CONSULTANT INFO:</p>		<p>NEW ELEMENTARY SCHOOL (K-5)</p> <h1>VENETIAN PARC WEST</h1> <p>SOUTHWEST 157th AVENUE and 174th STREET MIAMI, FL. 33187 MDCPS PROJECT No. 01892600</p>	<p>KEY PLAN</p>	<p>CONSULTANT INFO:</p>	<p>RODRIGUEZ ARCHITECTS INCORPORATED 2121 PONCE DE LEON BLVD. STE. 1010 CORAL GABLES, FL. 33134 TEL: (305) 448-3373 FAX: (305) 448-3374 A A C — 0 0 1 9 3 3</p>	<p>RAI</p>	<p>REVISIONS:</p> <table border="1"> <tr><td> </td><td> </td></tr> <tr><td> </td><td> </td></tr> <tr><td> </td><td> </td></tr> <tr><td> </td><td> </td></tr> </table>									<p>DRAWING TITLE:</p> <p>BUILDING SECTIONS</p> <p>SCALE AS NOTED</p> <p>ISSUE DATE: 12.16.14 PROJECT NO: 1906 SHEET: A-604</p>

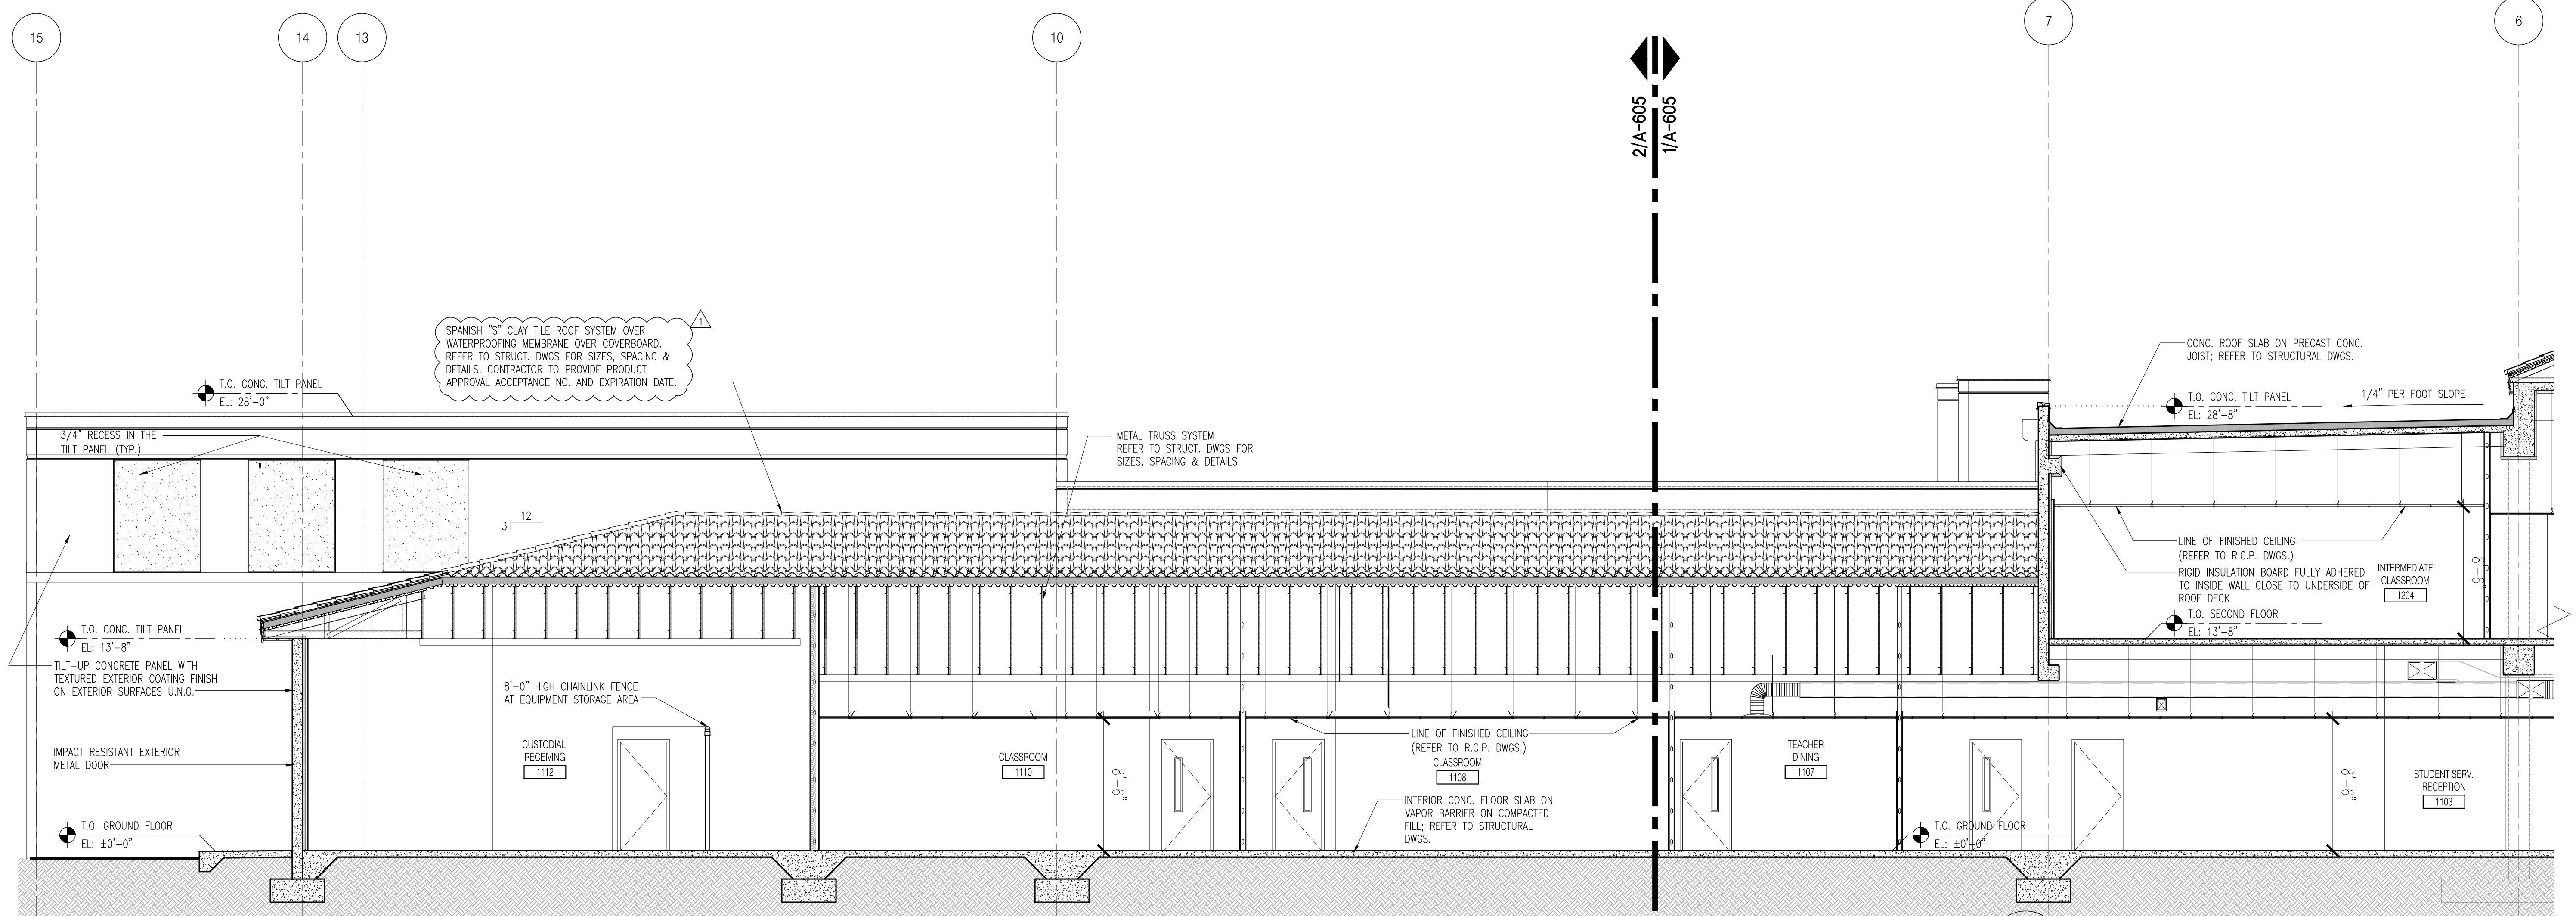


2 BUILDING SECTION

A-605 Scale: 3/16" = 1'-0"

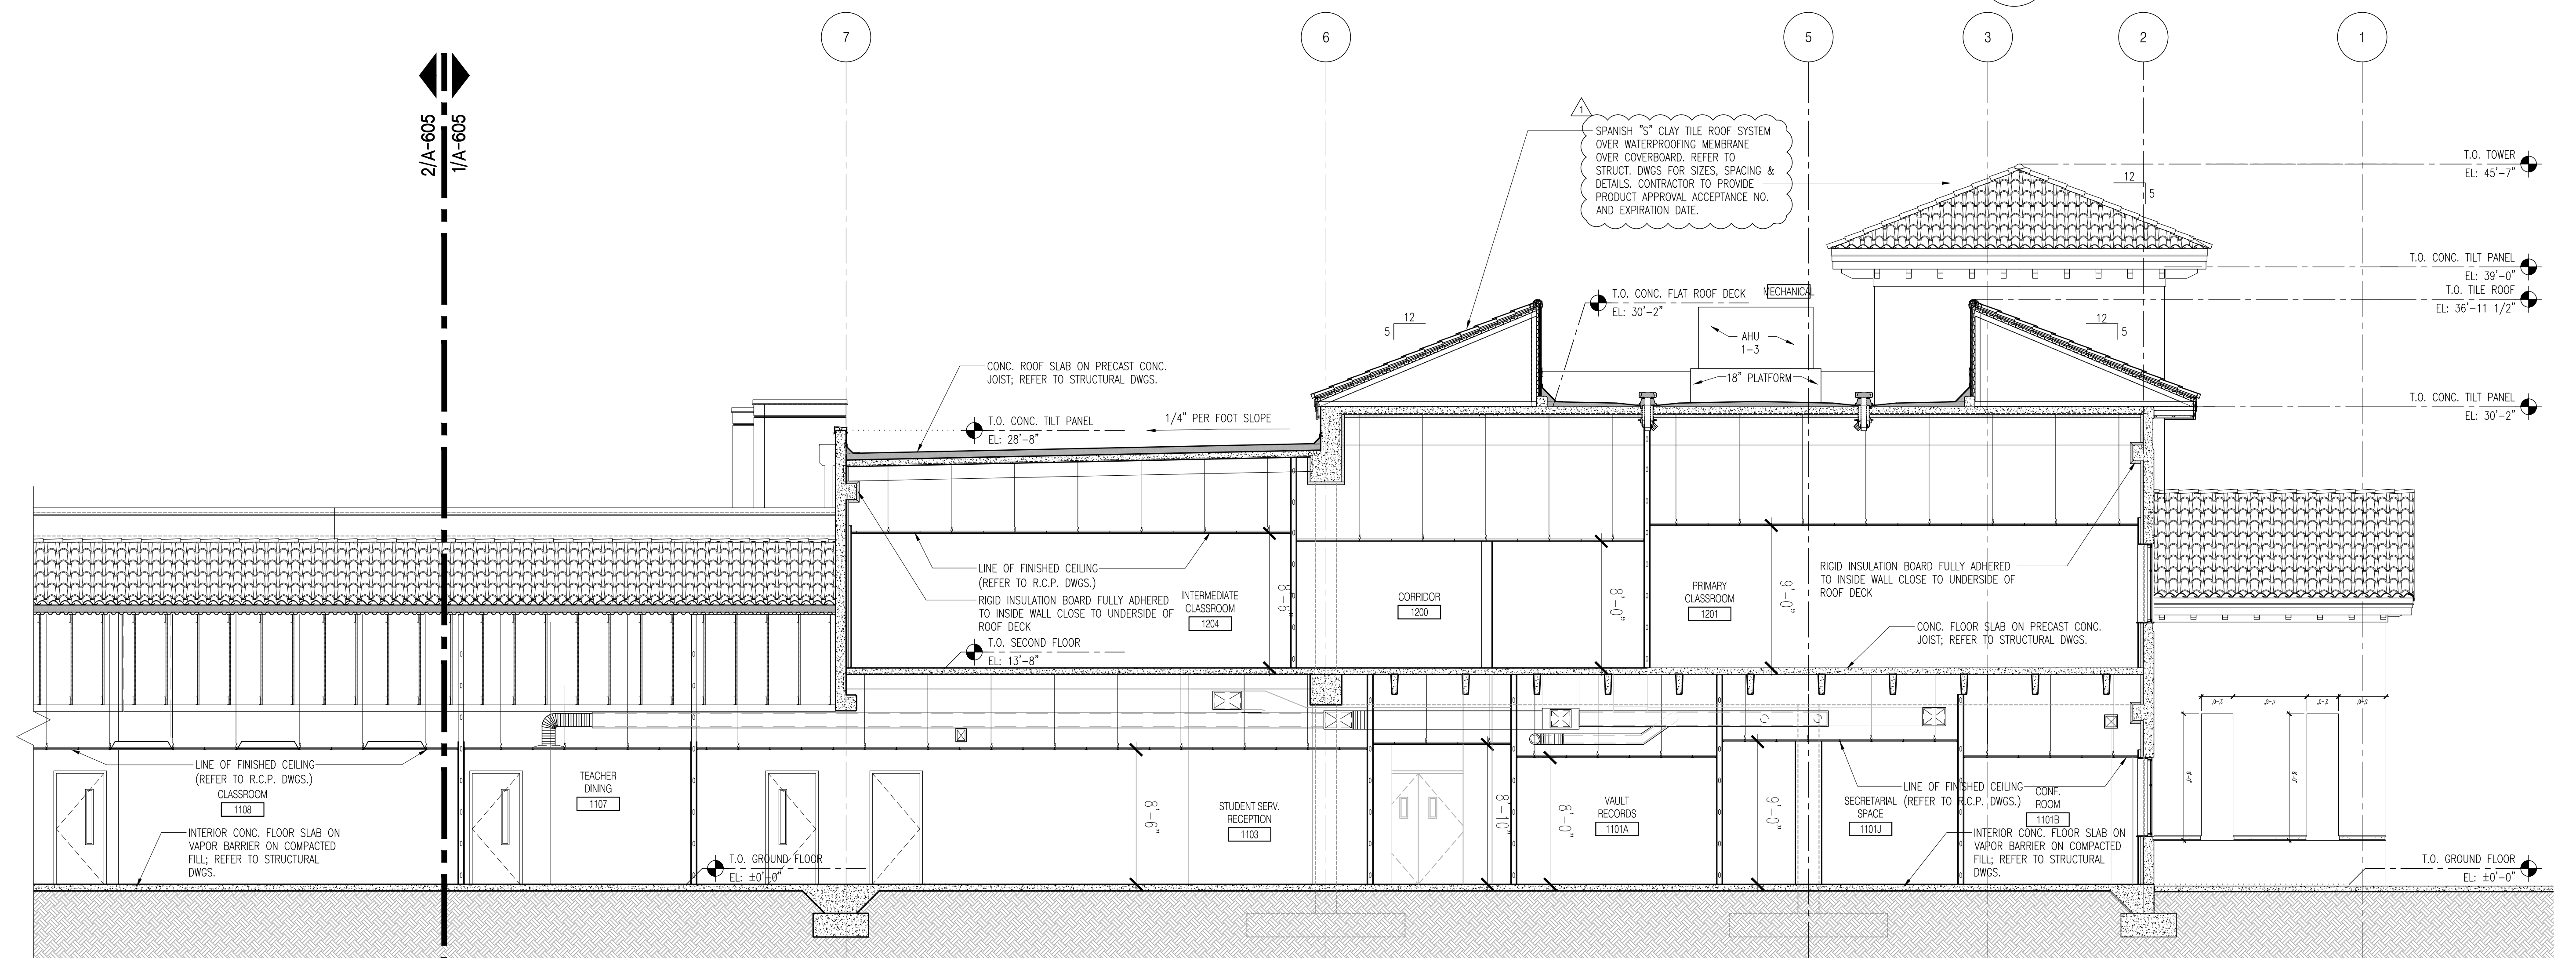


1 BUILDING SECTION


A-605 Scale: 3/16" = 1'-0"

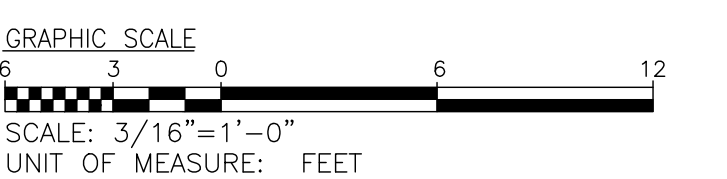

<p>CHECKED BY: LR.</p> <p>DRAWN BY: CV.</p>	<p>CONSULTANT INFO:</p> <p>MIAMI-DADE COUNTY giving our students the world PUBLIC SCHOOLS</p> <p>NEW ELEMENTARY SCHOOL (K-5) VENETIAN PARC WEST SOUTHWEST 157th AVENUE and 174th STREET MIAMI, FL. 33187 MDCPS PROJECT No. 01892600</p>	<p>KEY PLAN</p>	<p>CONSULTANT INFO:</p> <p>RODRIGUEZ ARCHITECTS INCORPORATED 2121 PONCE DE LEON BLVD. STE 1010 CORAL GABLES, FL. 33134 TEL: (305) 448-3373 FAX: (305) 448-3374 AAC - 001933</p>	<p>REVISIONS:</p> <p>02/14/2020 BUILDING DEPARTMENT COMMENTS</p>	<p>BUILDING SECTIONS</p> <p>SCALE AS NOTED</p> <p>ISSUE DATE: 12/16/19</p> <p>PROJECT NO: 1906</p> <p>SHEET: A-605</p>
---	--	-----------------	---	--	--

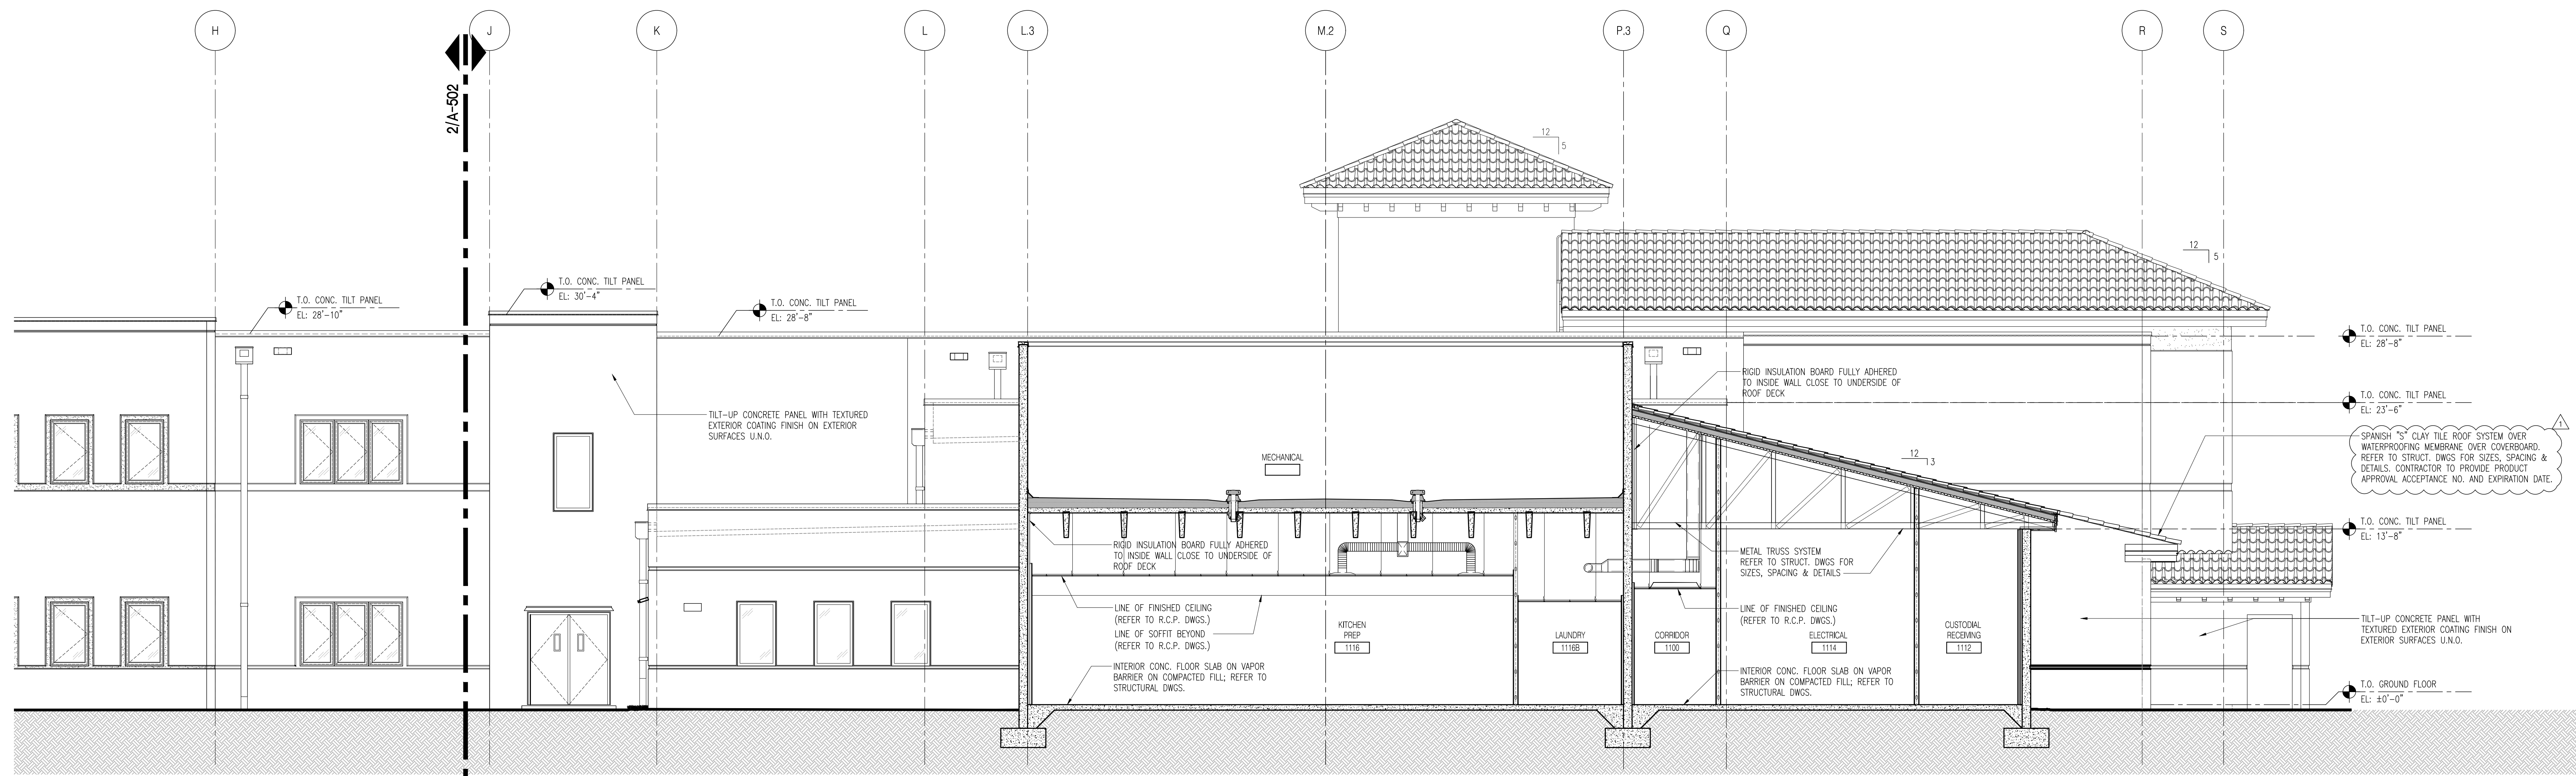


1 BUILDING SECTION
A-606 Scale: 3/16" = 1'-0"

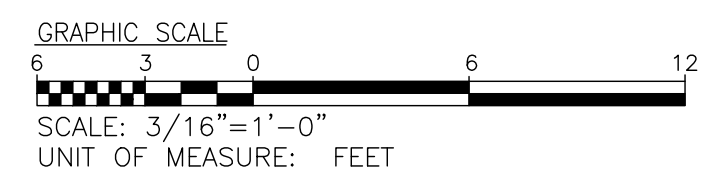


CHECKED BY: LR.	DRAWN BY: C.V.
--------------------	-------------------

CONSULTANT INFO:

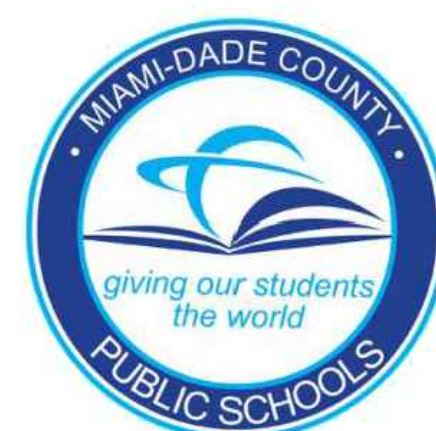

NEW ELEMENTARY SCHOOL (K-5)
VENETIAN PARC WEST
SOUTHWEST 157th AVENUE and 174th STREET
MIAMI, FL. 33187
MDCPS PROJECT No. 01892600

KEY PLAN

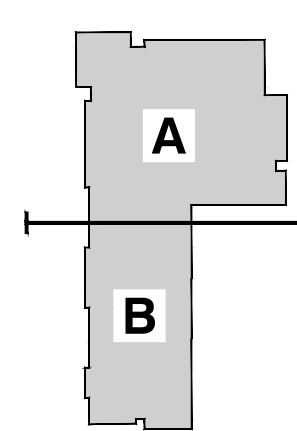

CONSULTANT INFO:

RODRIGUEZ ARCHITECTS
INCORPORATED
2121 PONCE DE LEON BLVD. STE 1010
CORAL GABLES, FL. 33134
TEL: (305) 448-3373
FAX: (305) 448-3374

**RODRIGUEZ
ARCHITECTS
INCORPORATED**
2121 PONCE DE LEON BLVD. STE 1010
CORAL GABLES, FL. 33134
TEL: (305) 448-3373
FAX: (305) 448-3374
A A C — 0 0 1 9 3 3



REVISIONS:

02.14.2020 BUILDING DEPARTMENT COMMENTS





DRAWING TITLE:





**BUILDING
SECTIONS**


SCALE AS NOTED

ISSUE DATE: 12.16.19 PROJECT NO: 1906


SHEET: A-606

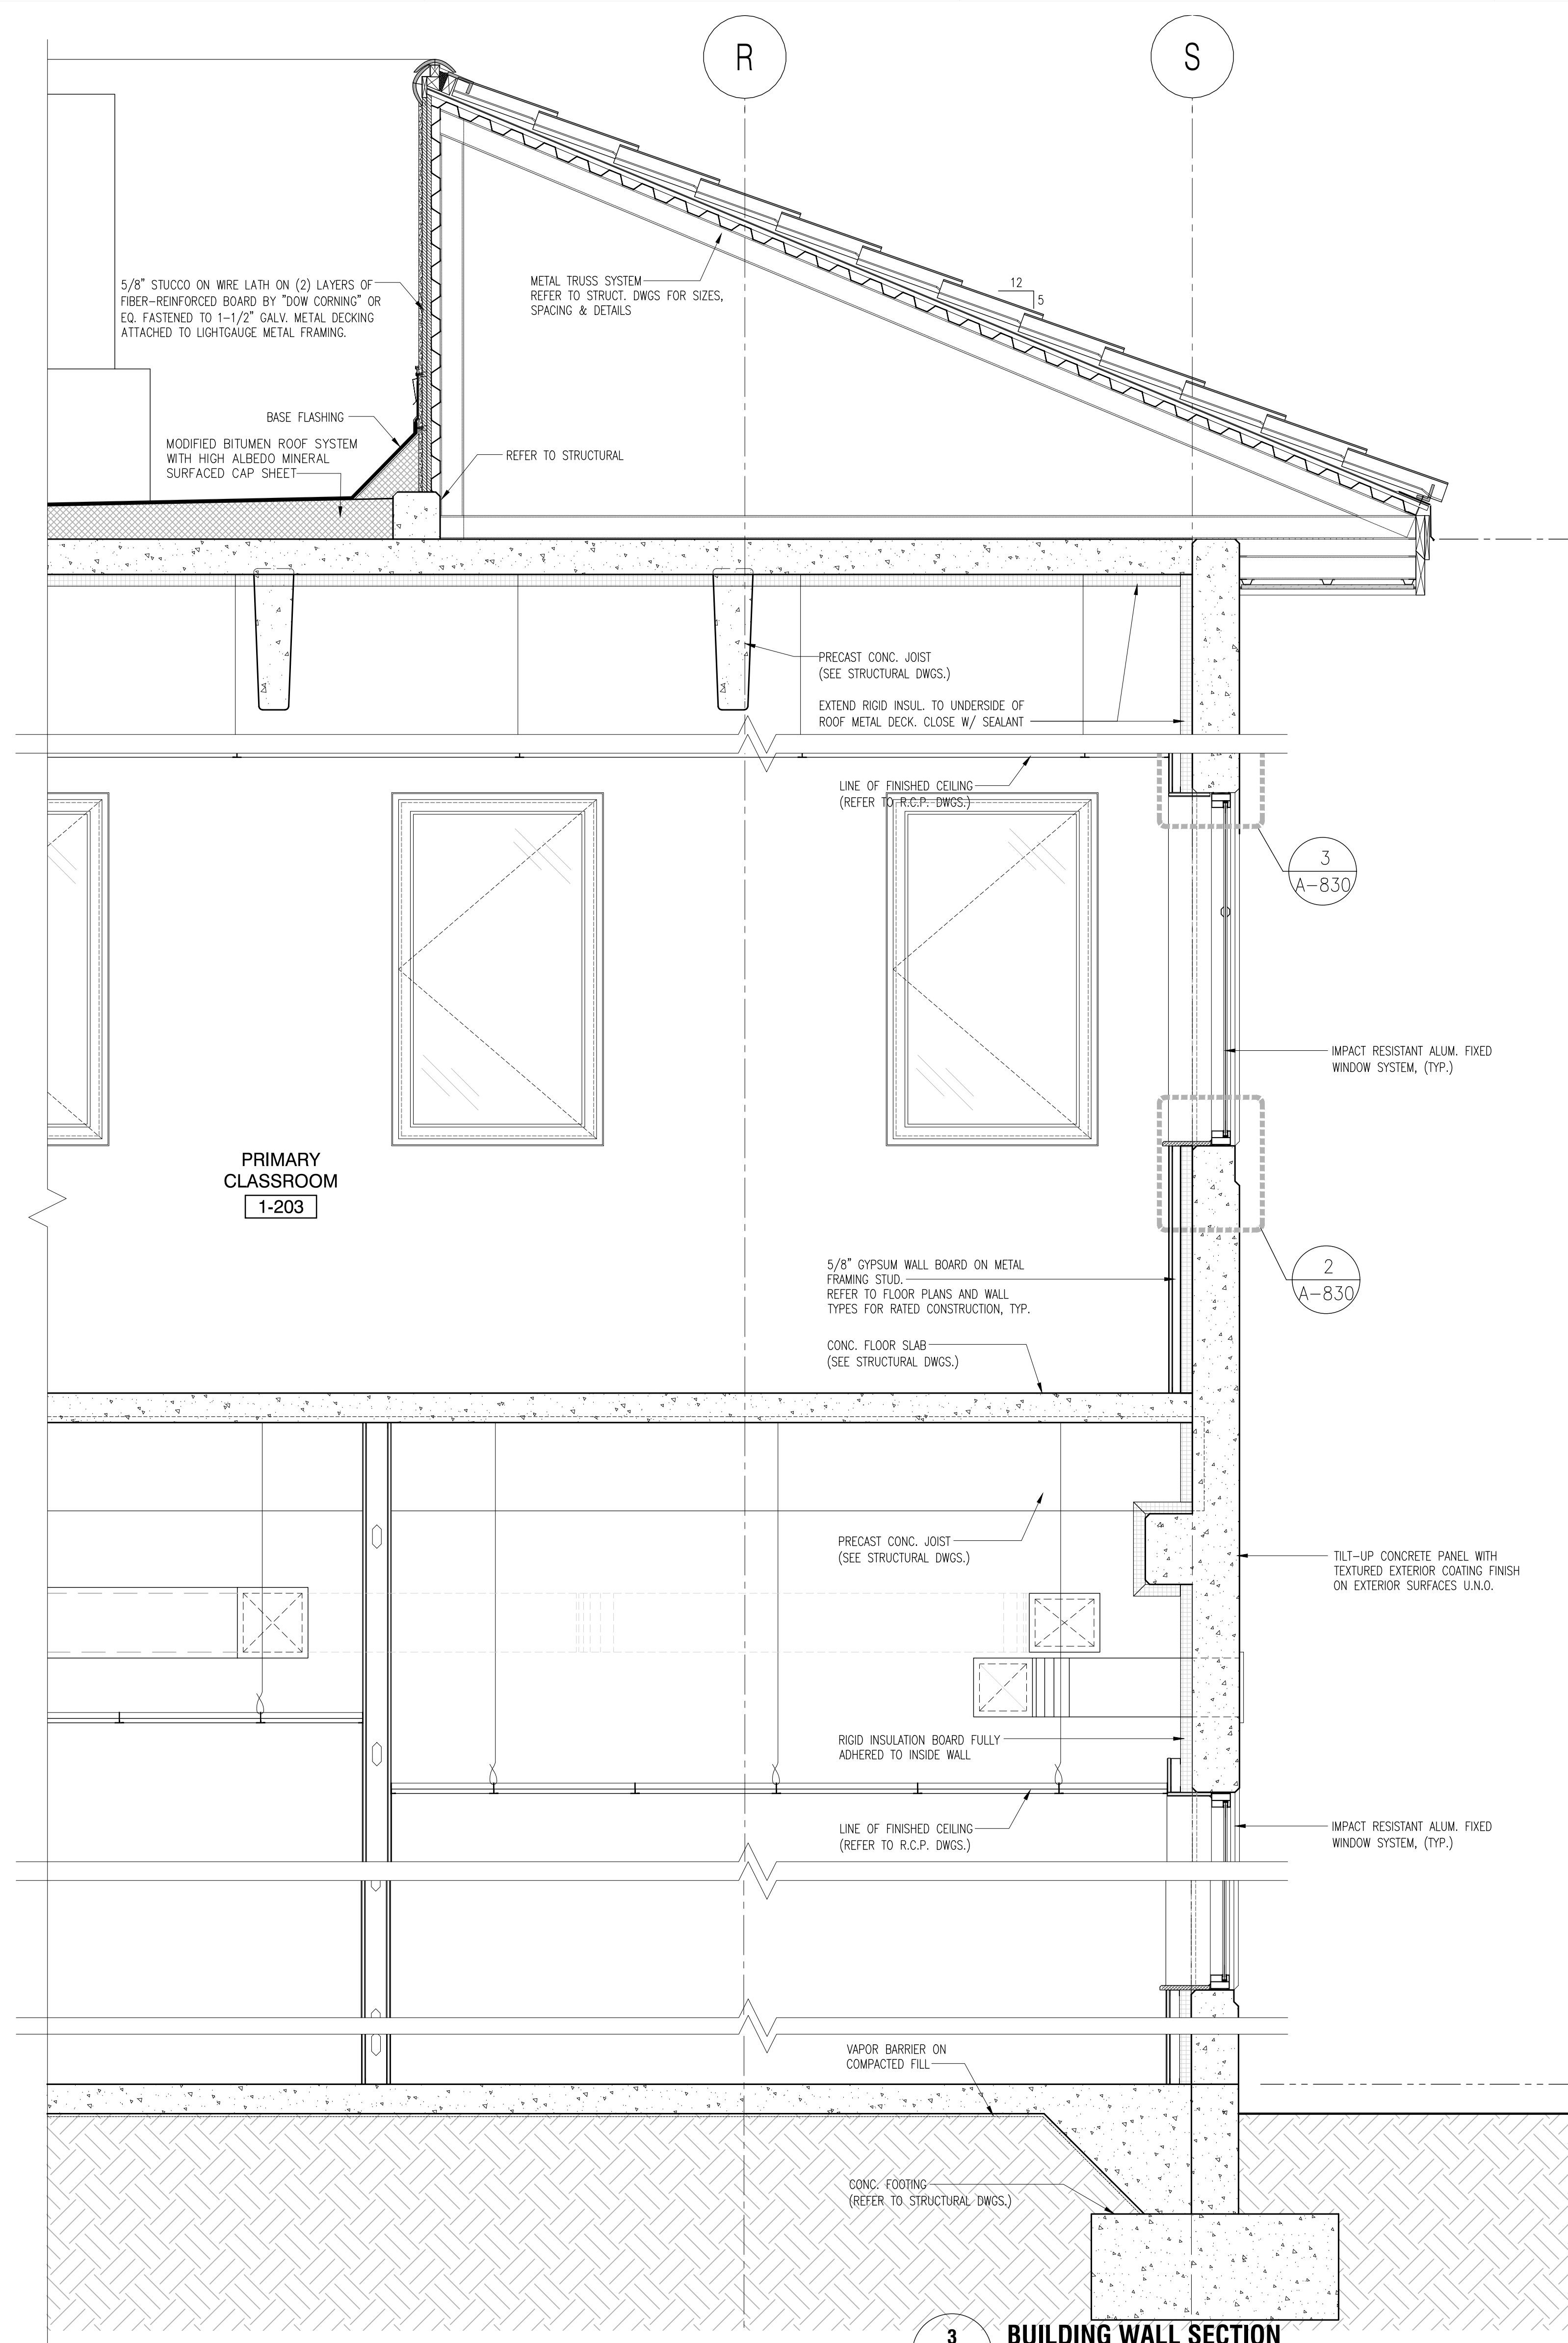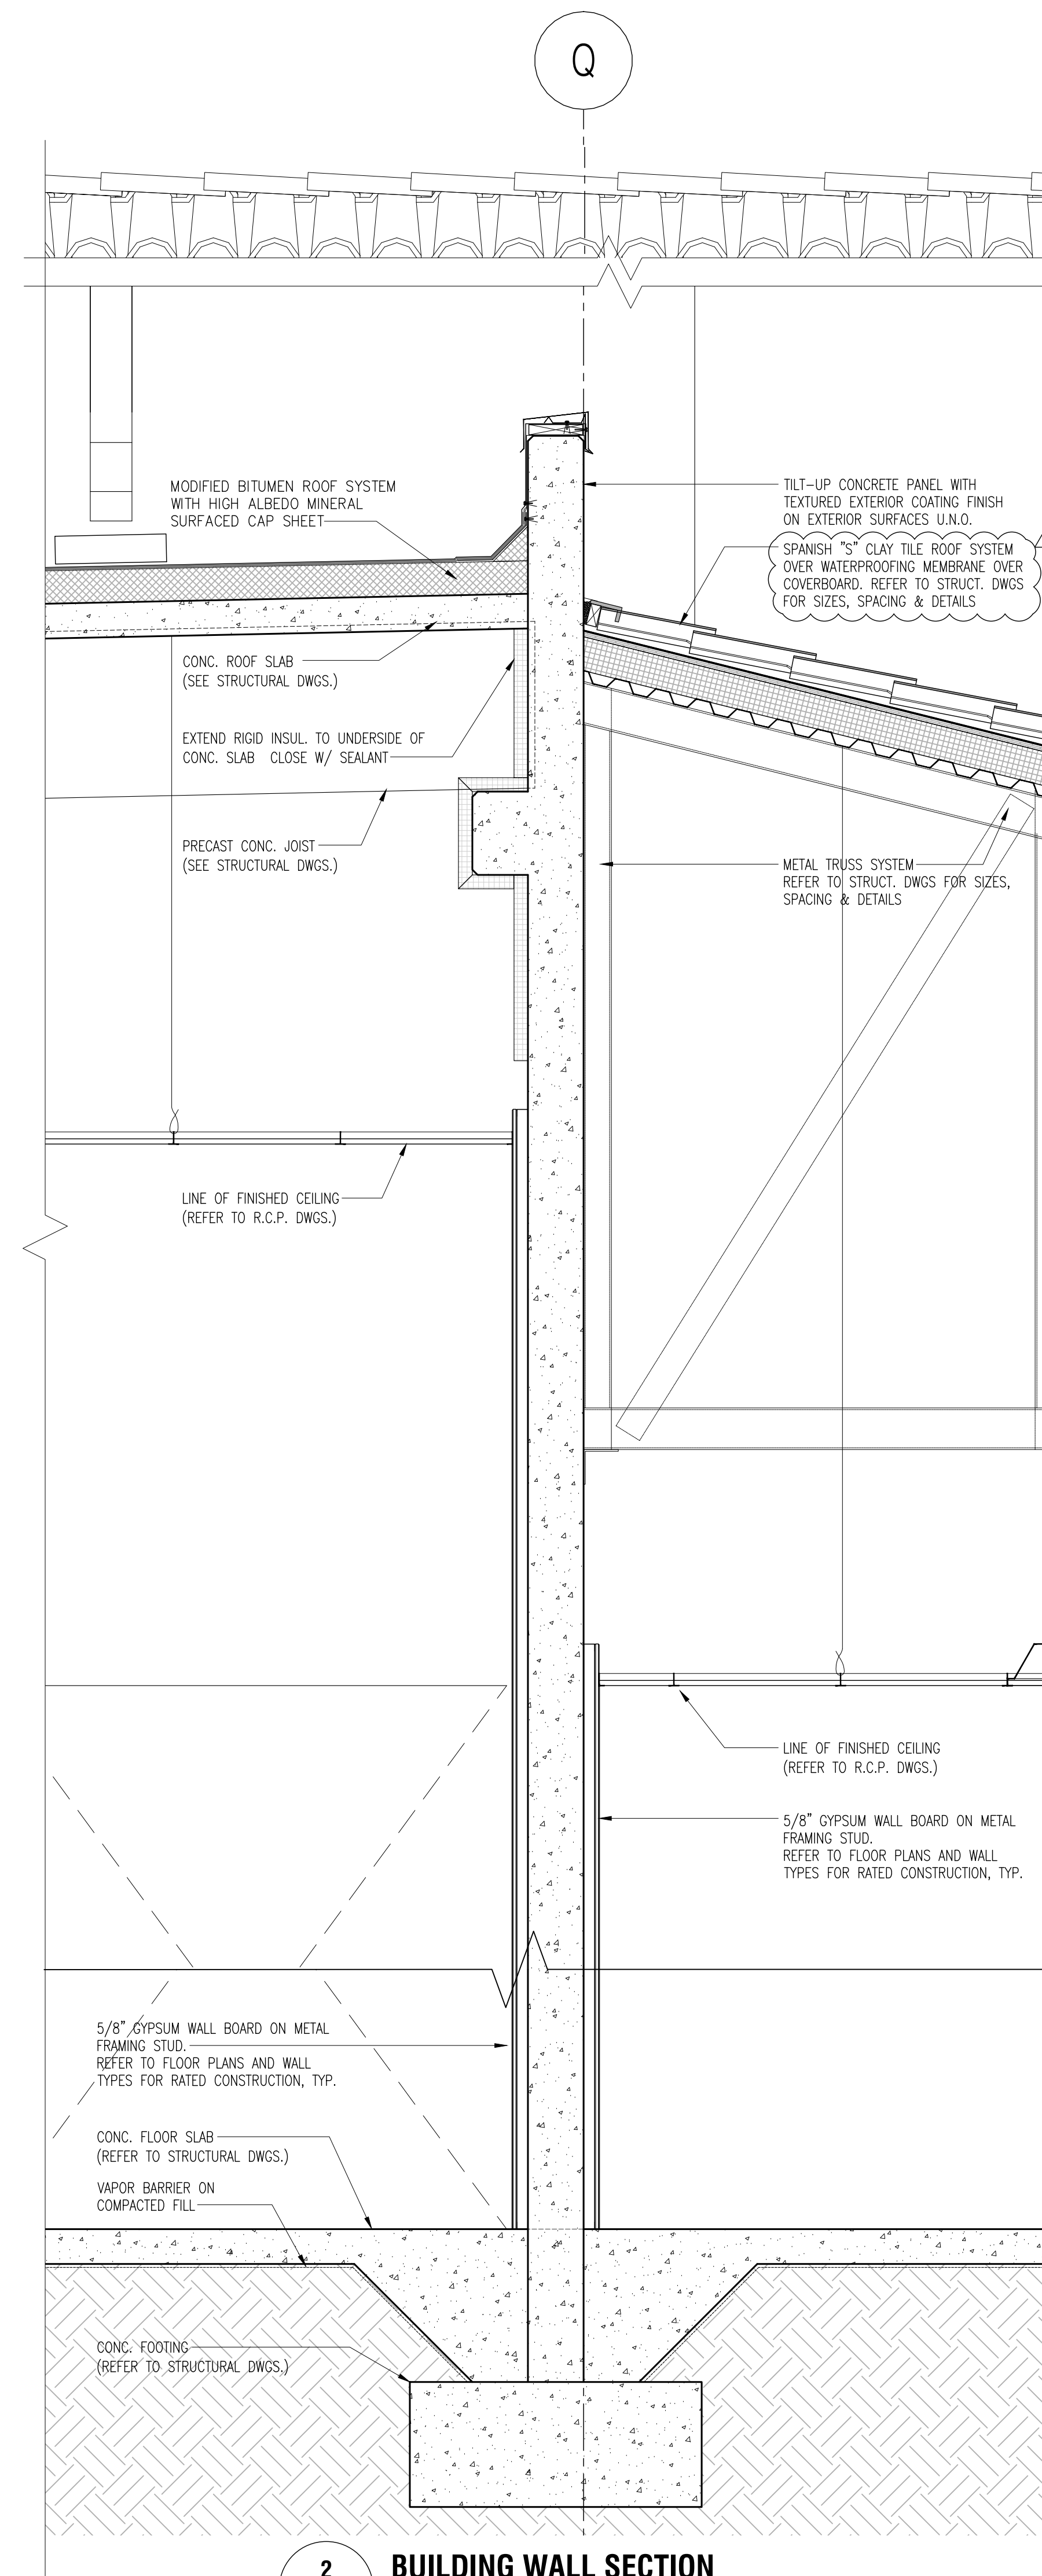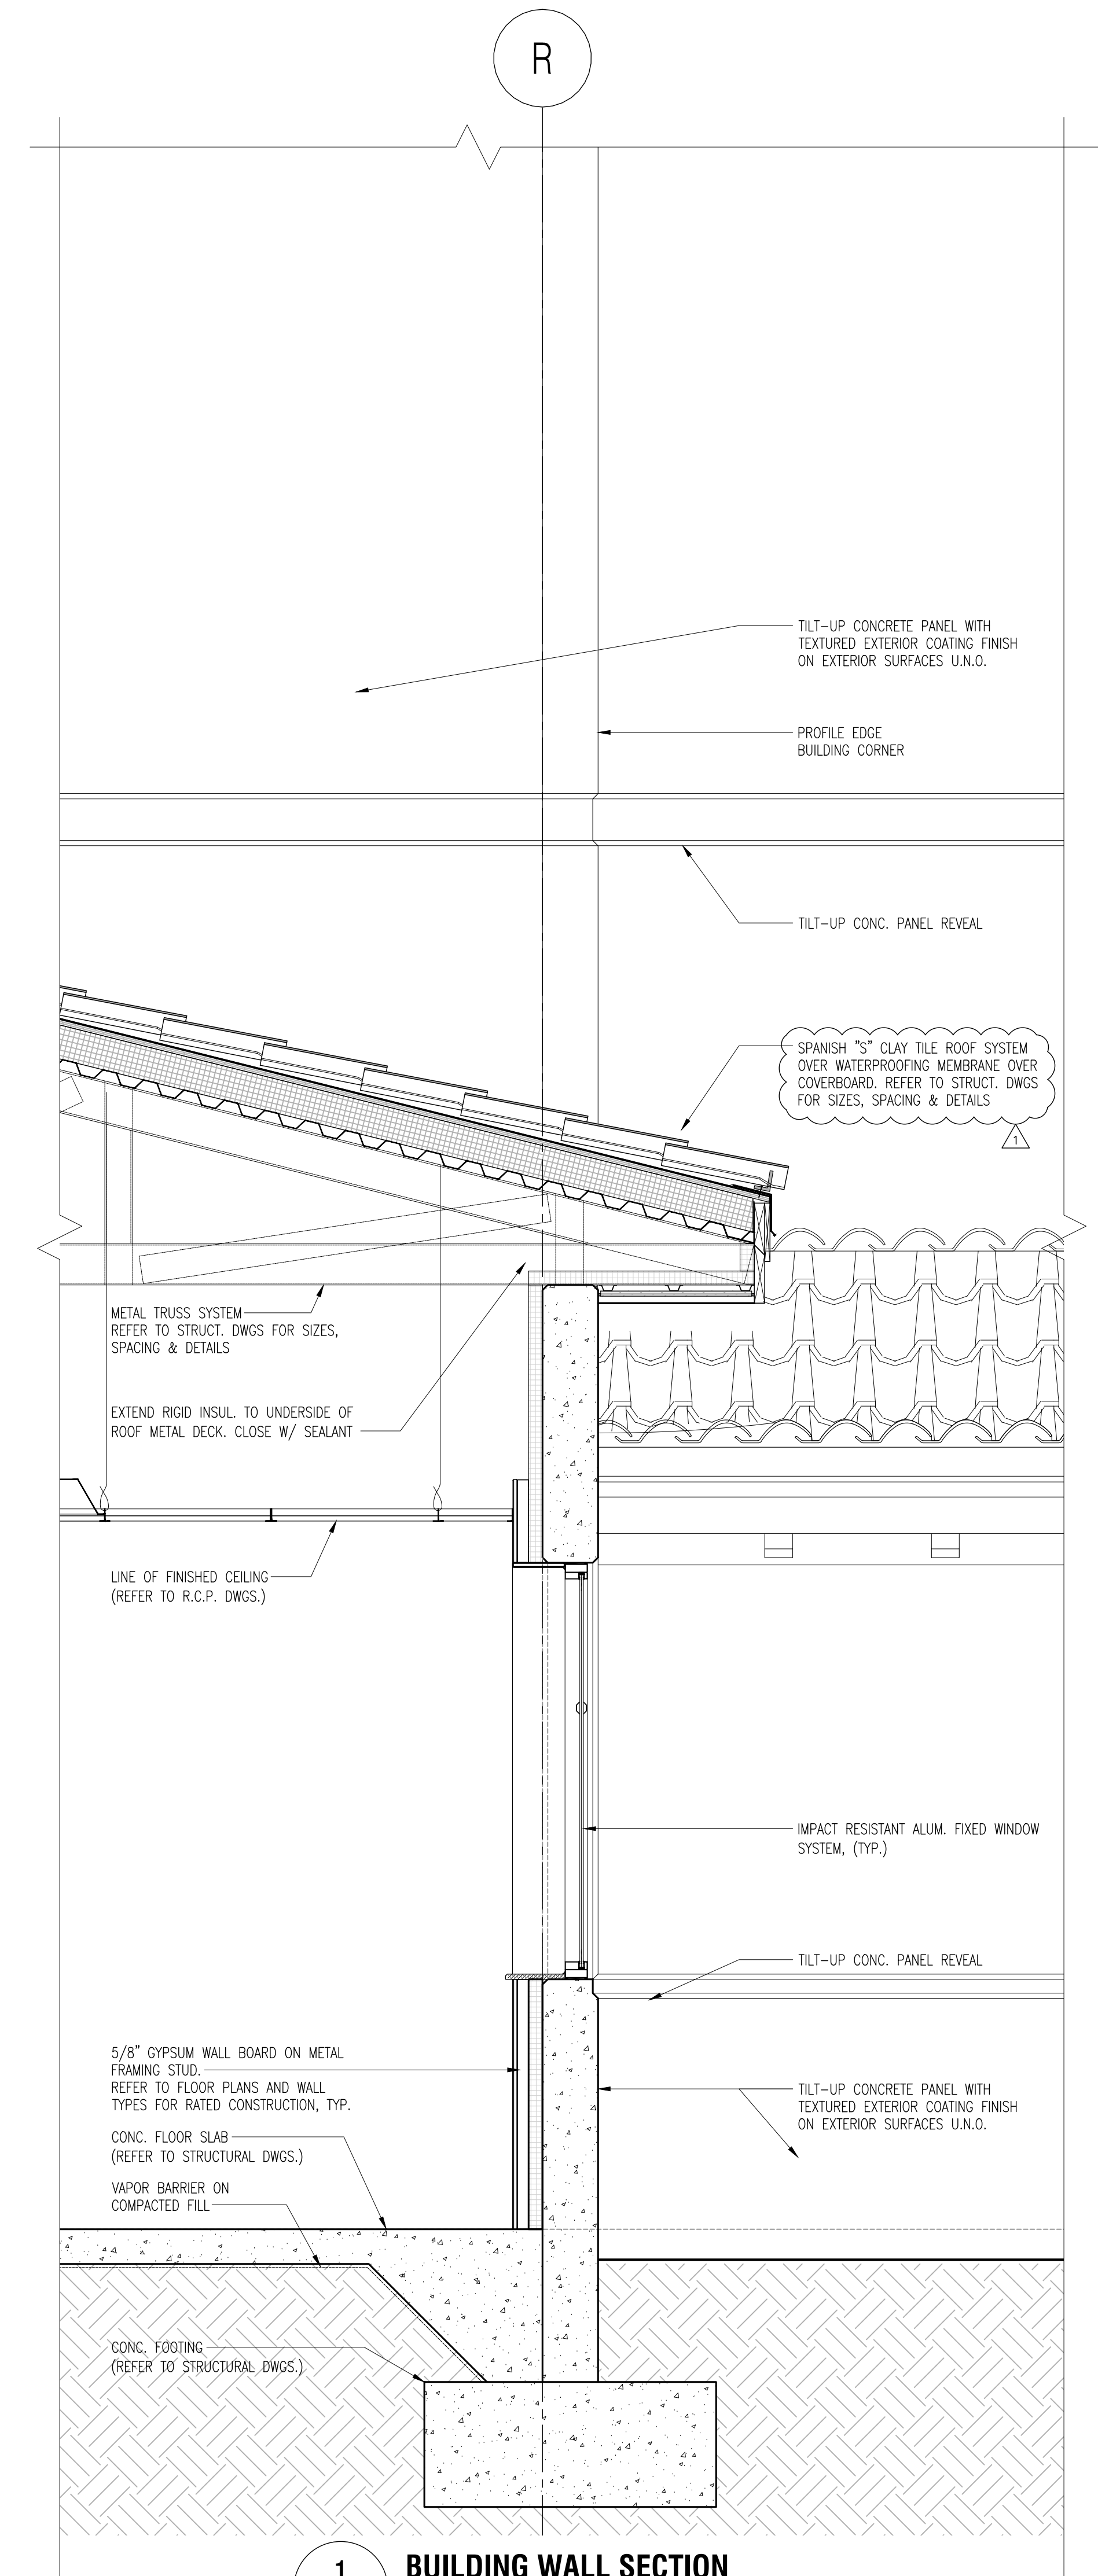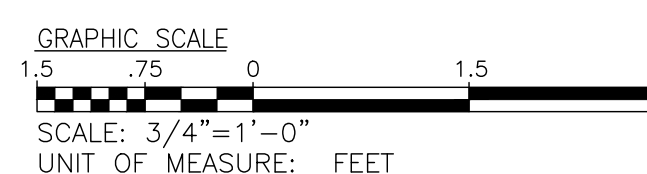

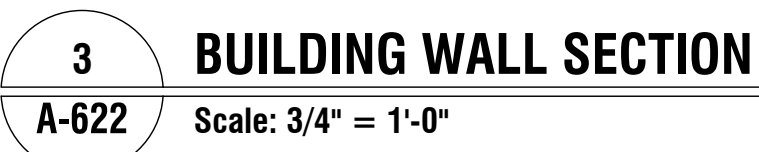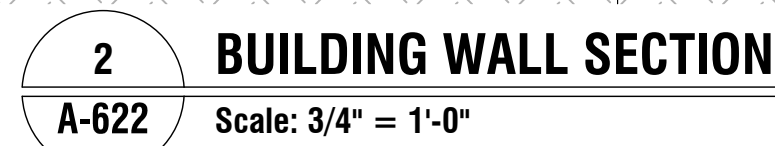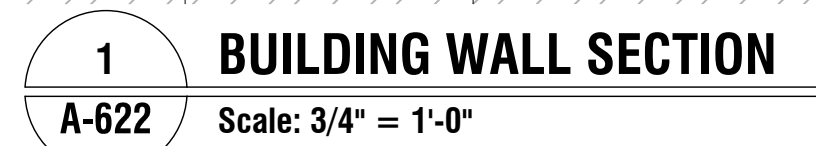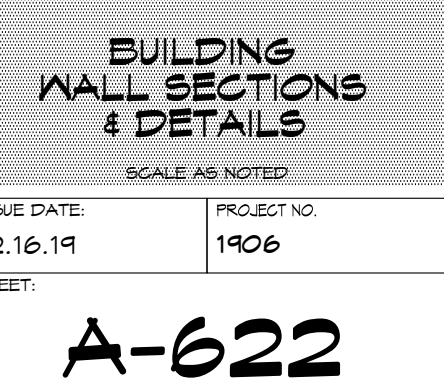


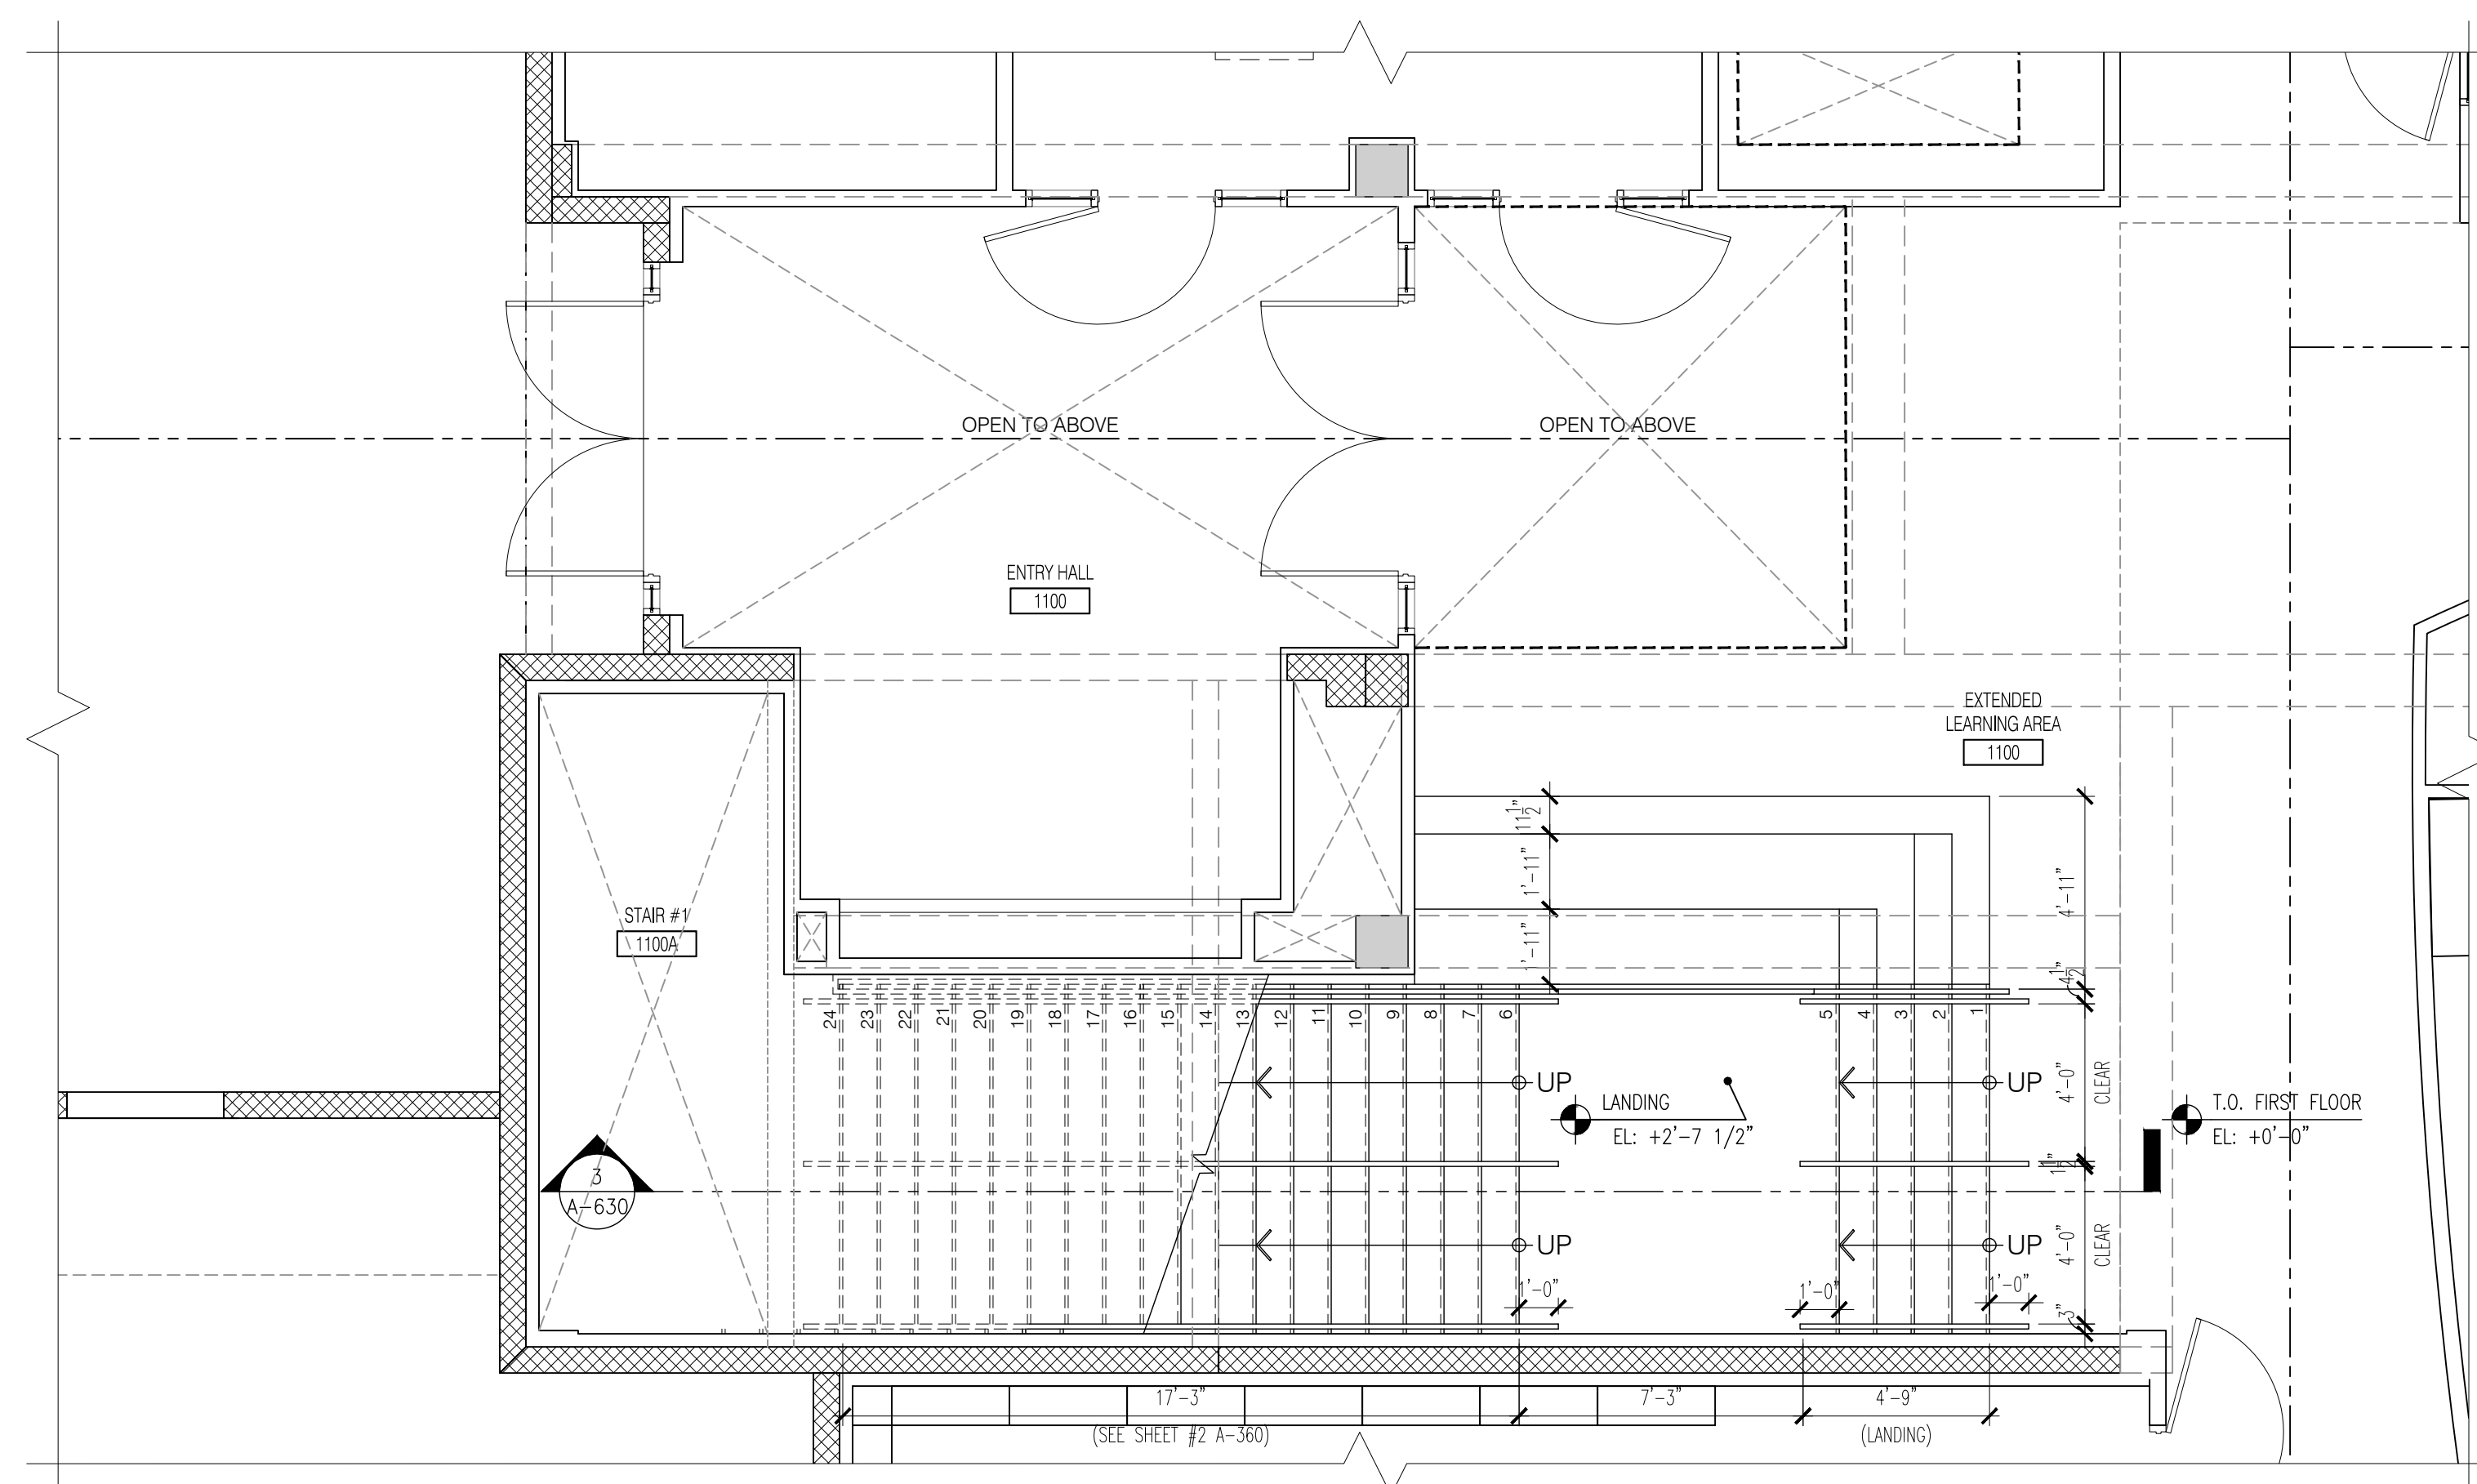

1 ENLARGED STAIR #1 PLAN - GROUND FLOOR
A-630 SCALE: 1/4" = 1'-0"

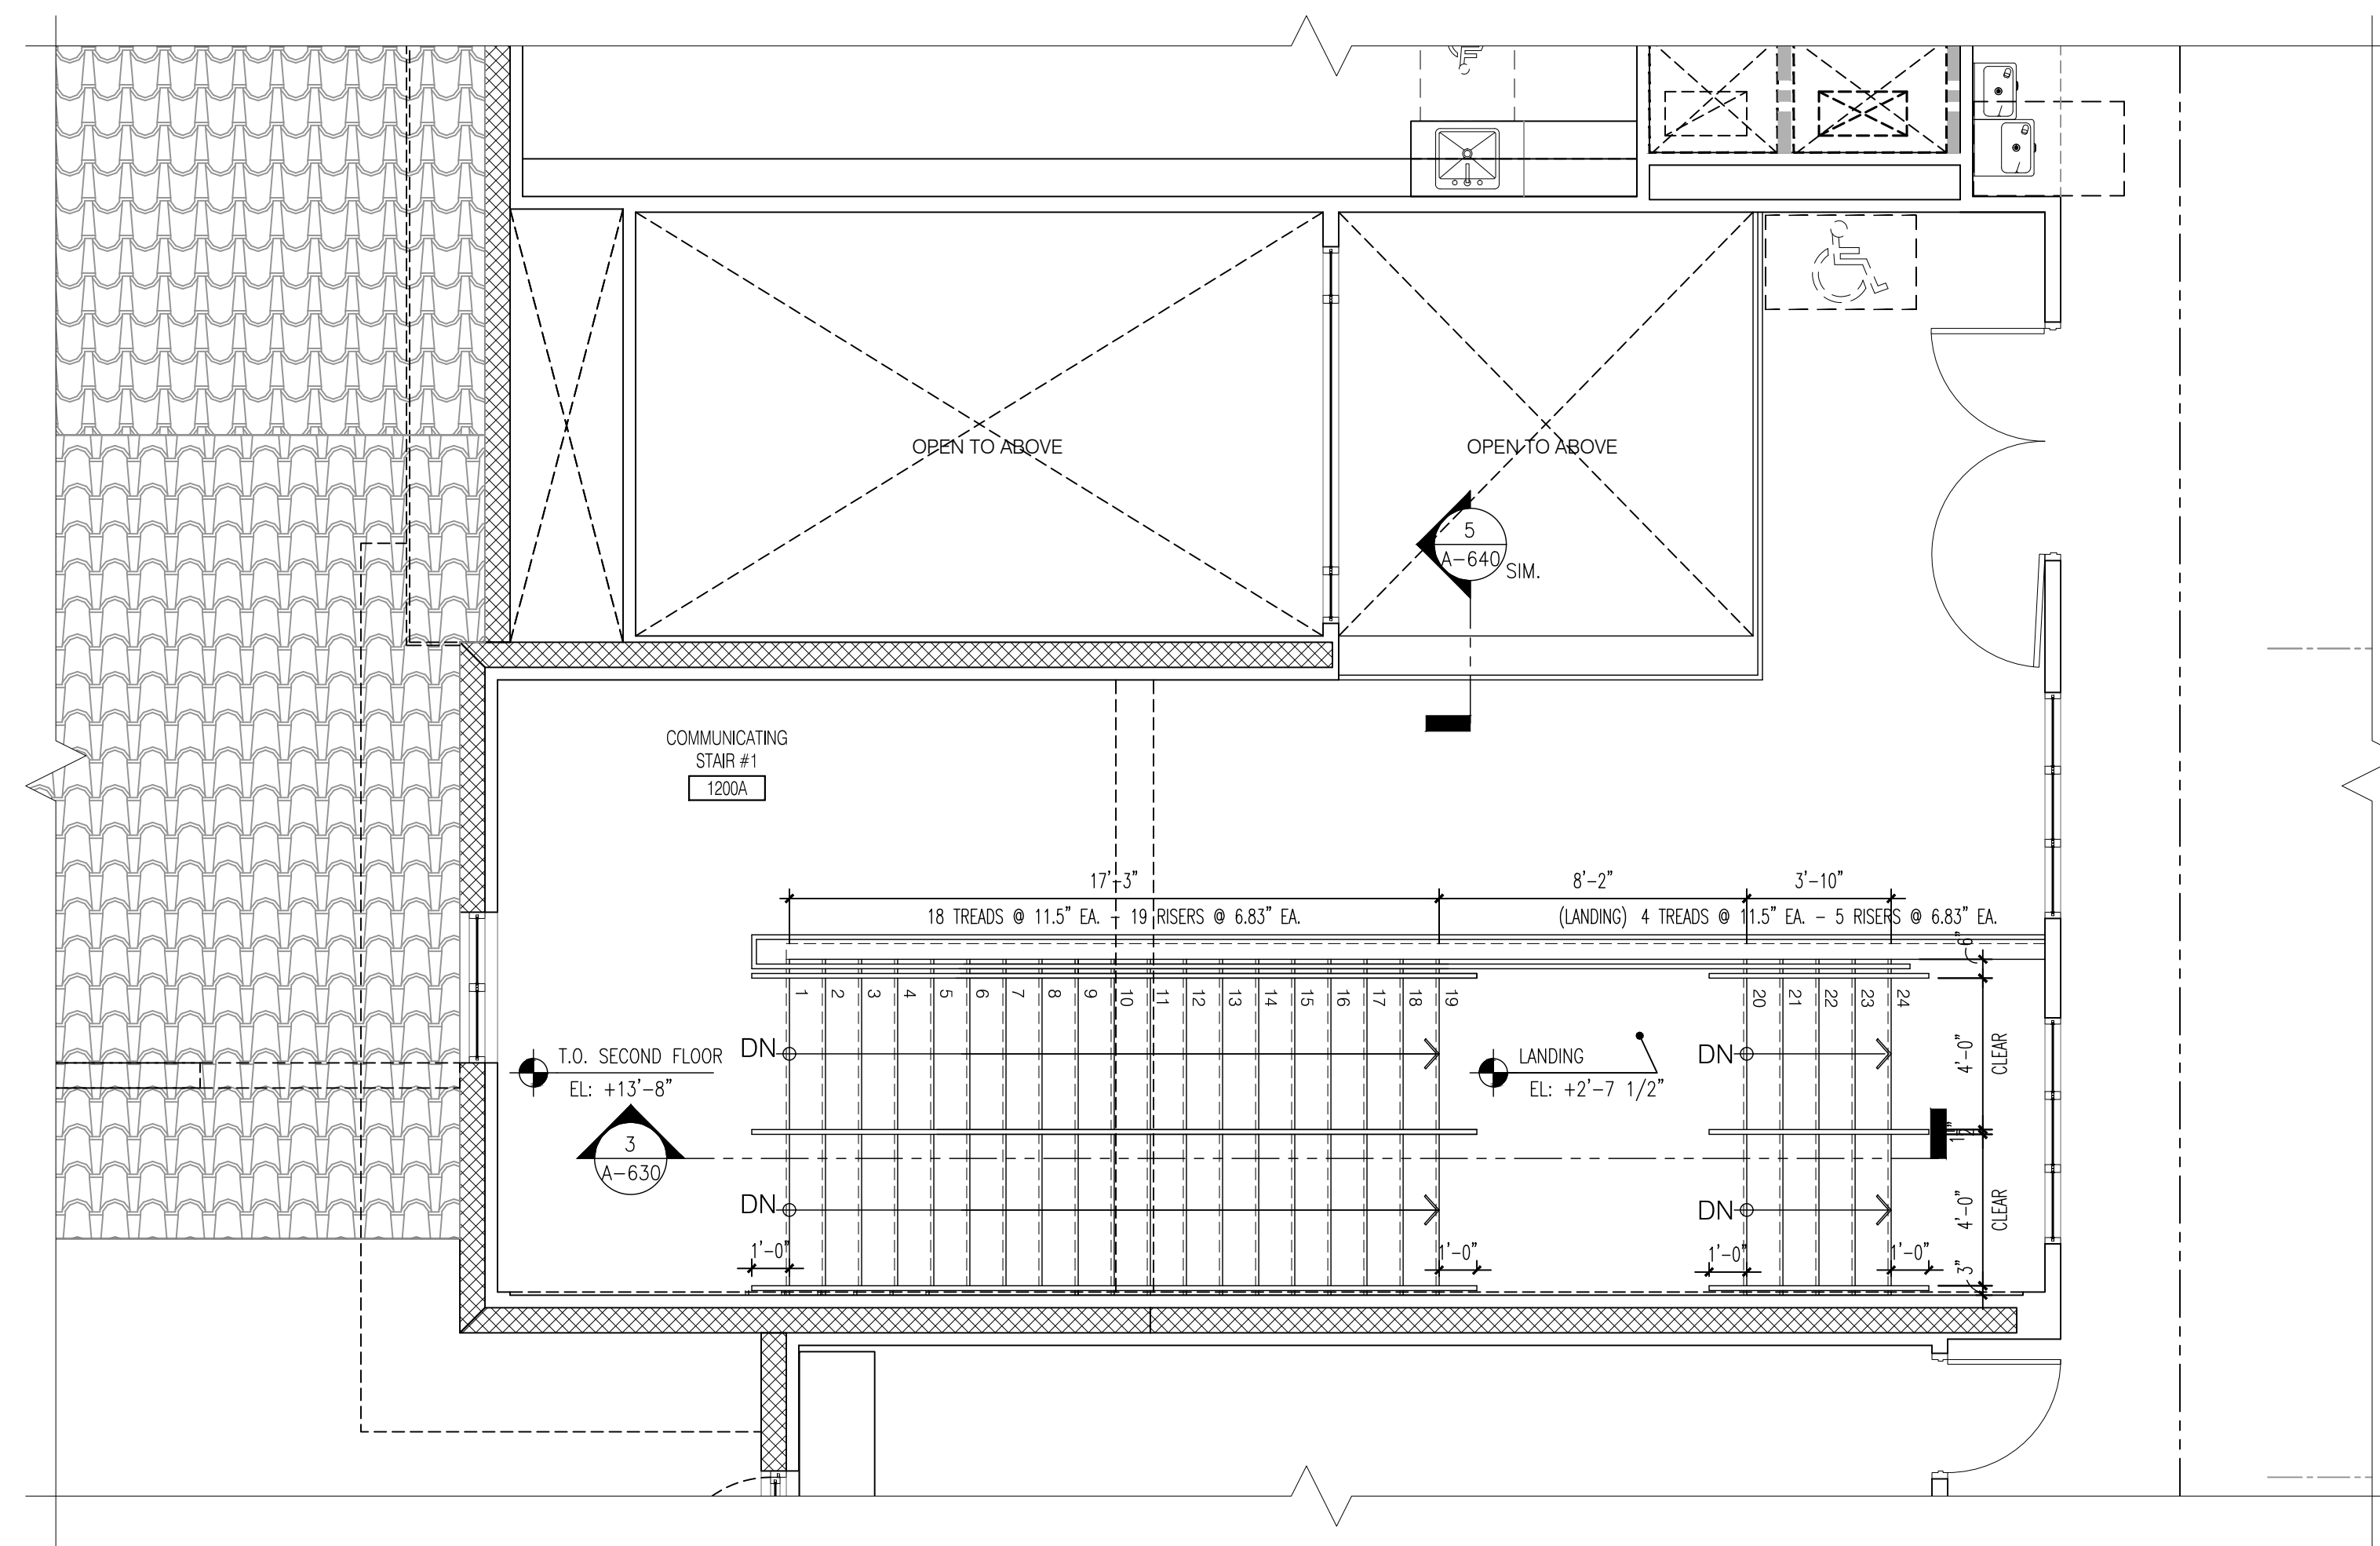


2 ENLARGED STAIR #1 PLAN - SECOND FLOOR
A-630 SCALE: 1/4" = 1'-0"

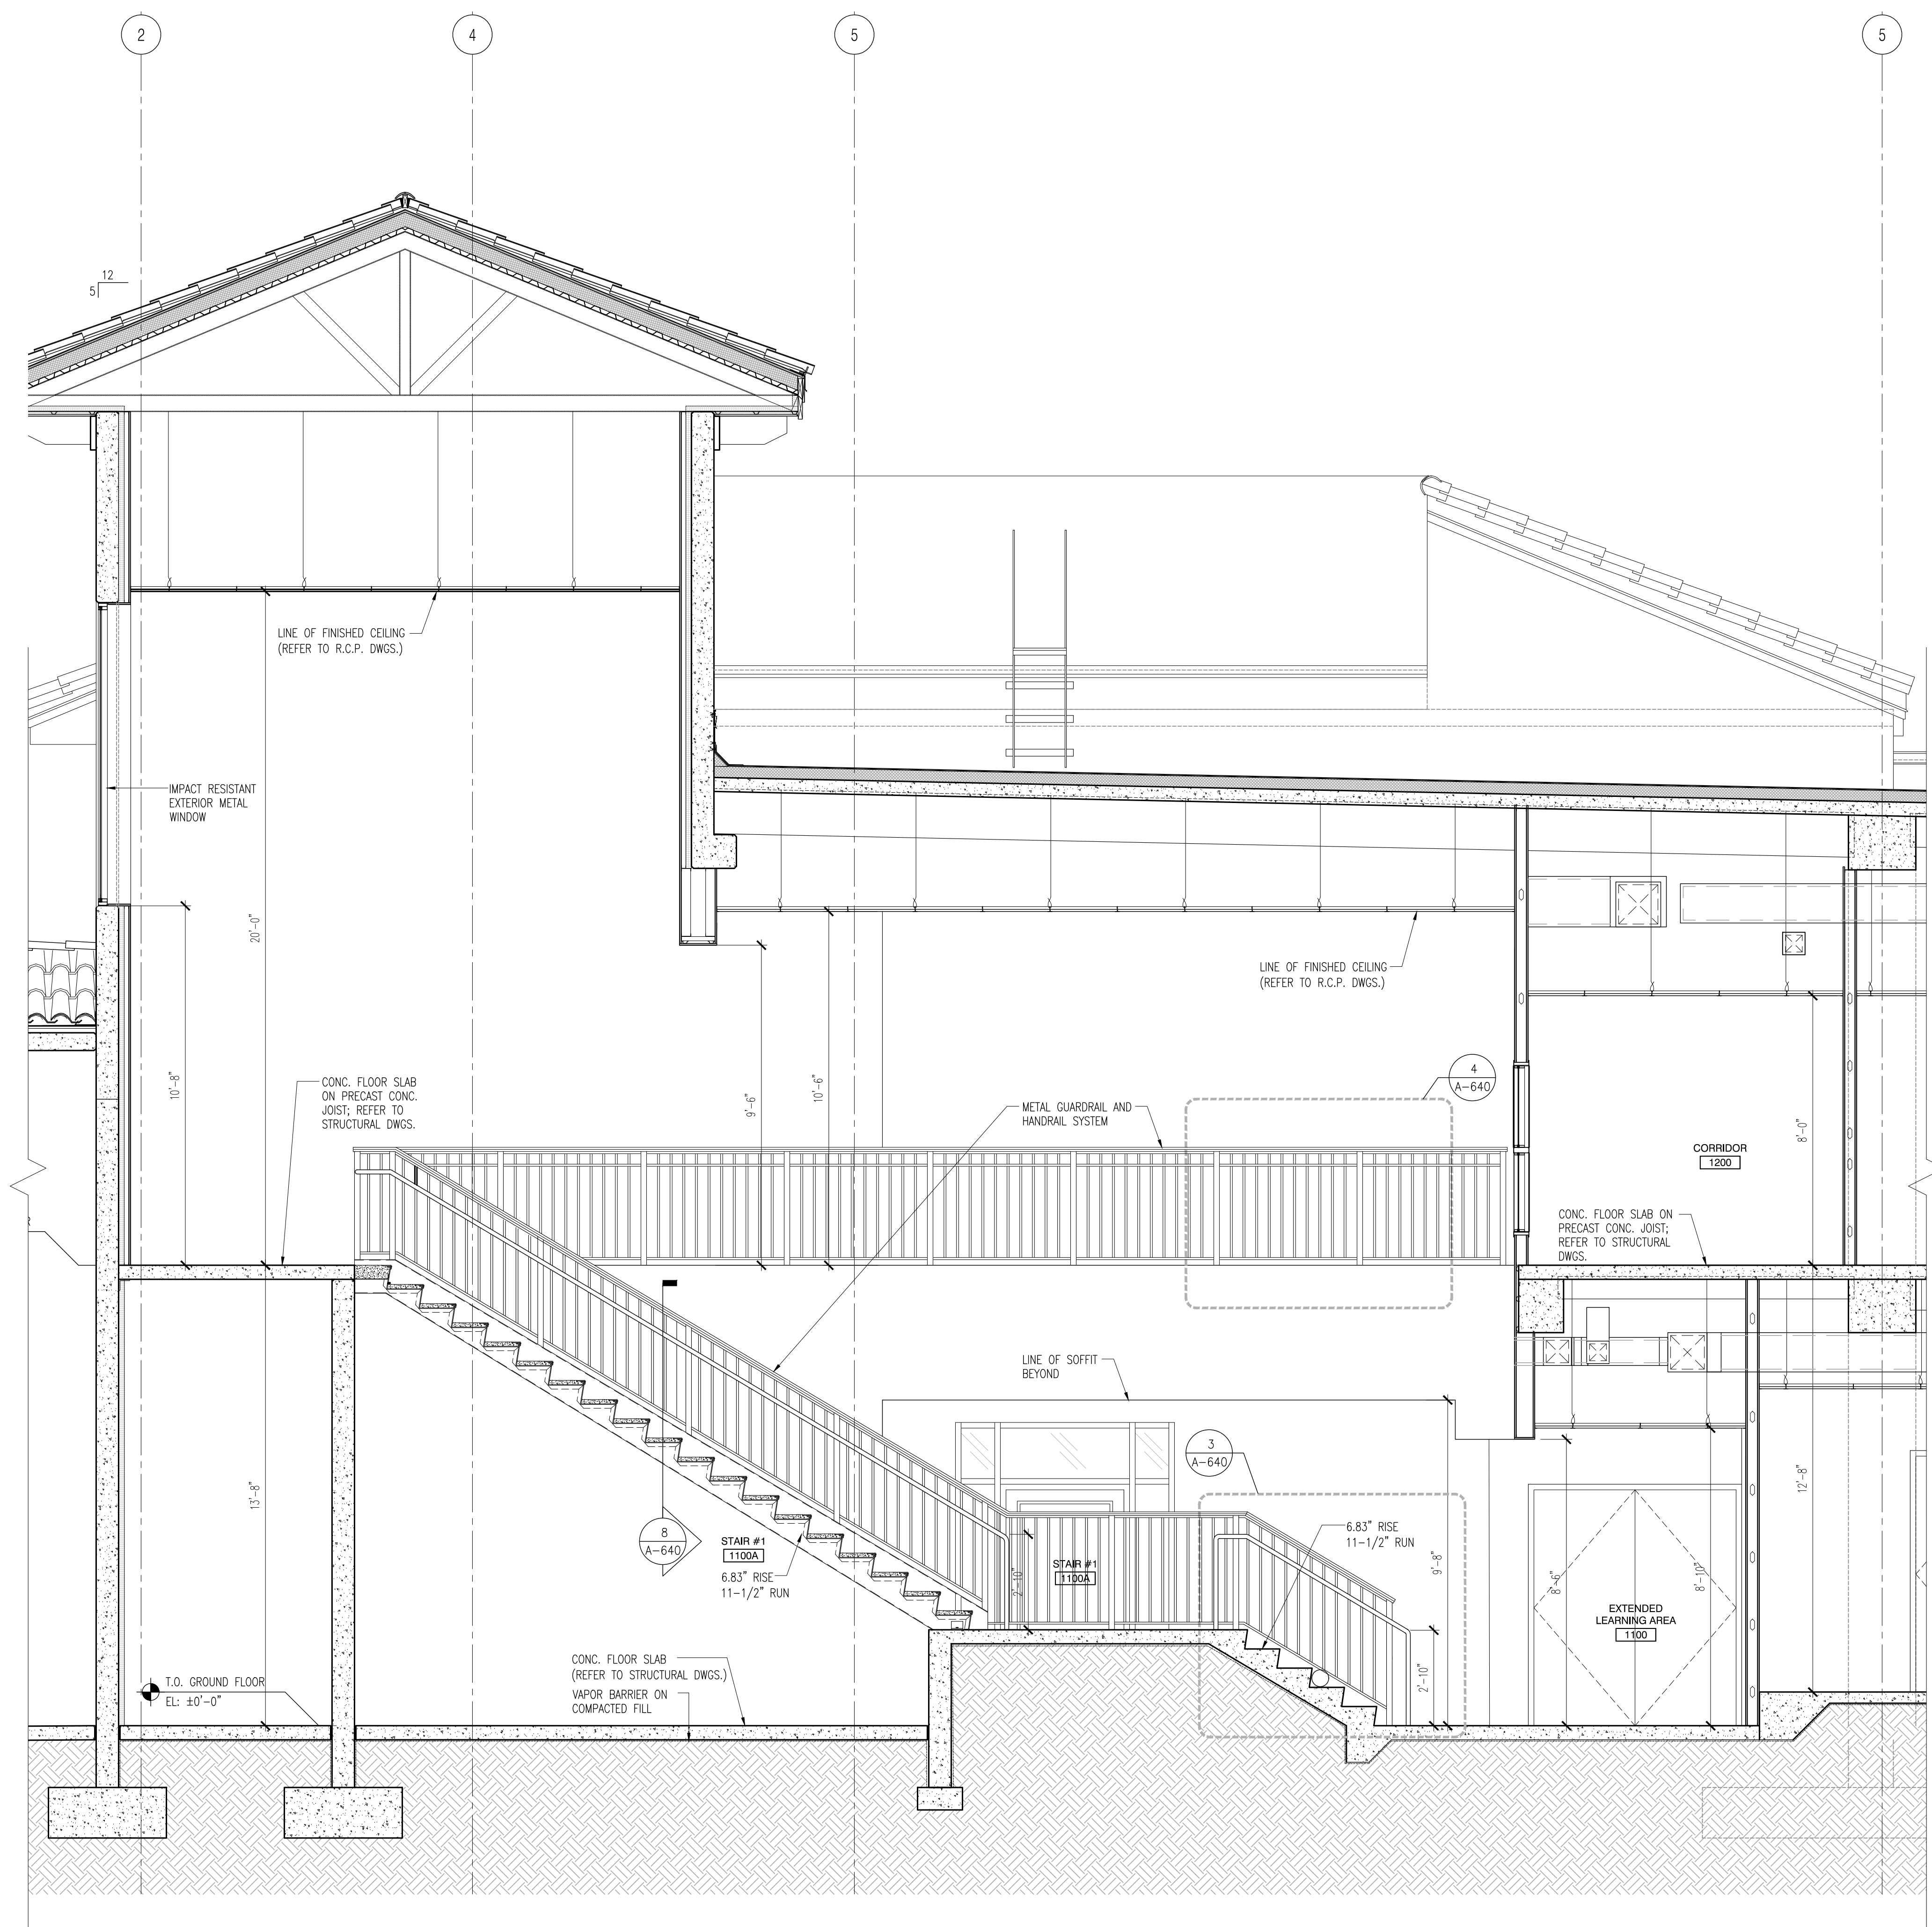

3 STAIR SECTION
A-630 SCALE: 3/8" = 1'-0"


CHECKED BY: LR	DRAWN BY: CV
-------------------	-----------------

CONSULTANT INFO:

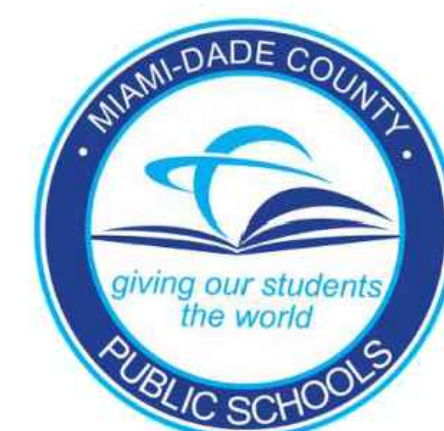

NEW ELEMENTARY SCHOOL (K-5)
VENETIAN PARC WEST
SOUTHWEST 157th AVENUE and 174th STREET
MIAMI, FL. 33187
MDCPS PROJECT No. 01892600


KEY PLAN

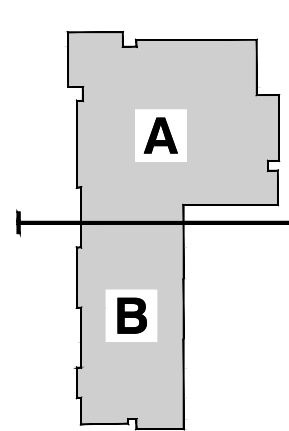

CONSULTANT INFO:


RODRIGUEZ ARCHITECTS, P.A.
FLORIDA ARCHITECTS' FIRM NO. 12001
EXPIRATION DATE 12/31/2021

RODRIGUEZ ARCHITECTS INCORPORATED
2121 PONCE DE LEON BLVD. STE. 1010
CORAL GABLES, FL. 33134
TEL: (305) 448-3373
FAX: (305) 448-3374
A A C - 0 0 1 9 3 3

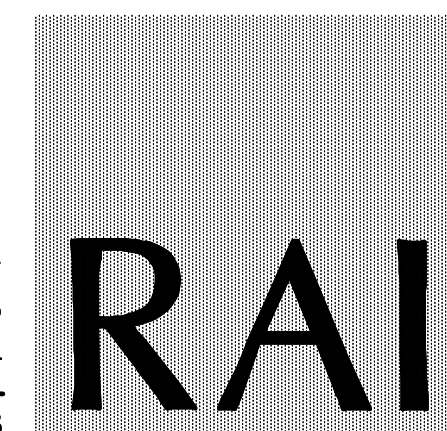


REVISIONS:


DRAWING TITLE:
ENLARGED STAIR #1 PLANS & SECTIONS
SCALE: AS NOTED
ISSUE DATE: 12/16/19
PROJECT NO: 1906
SHEET: A-630

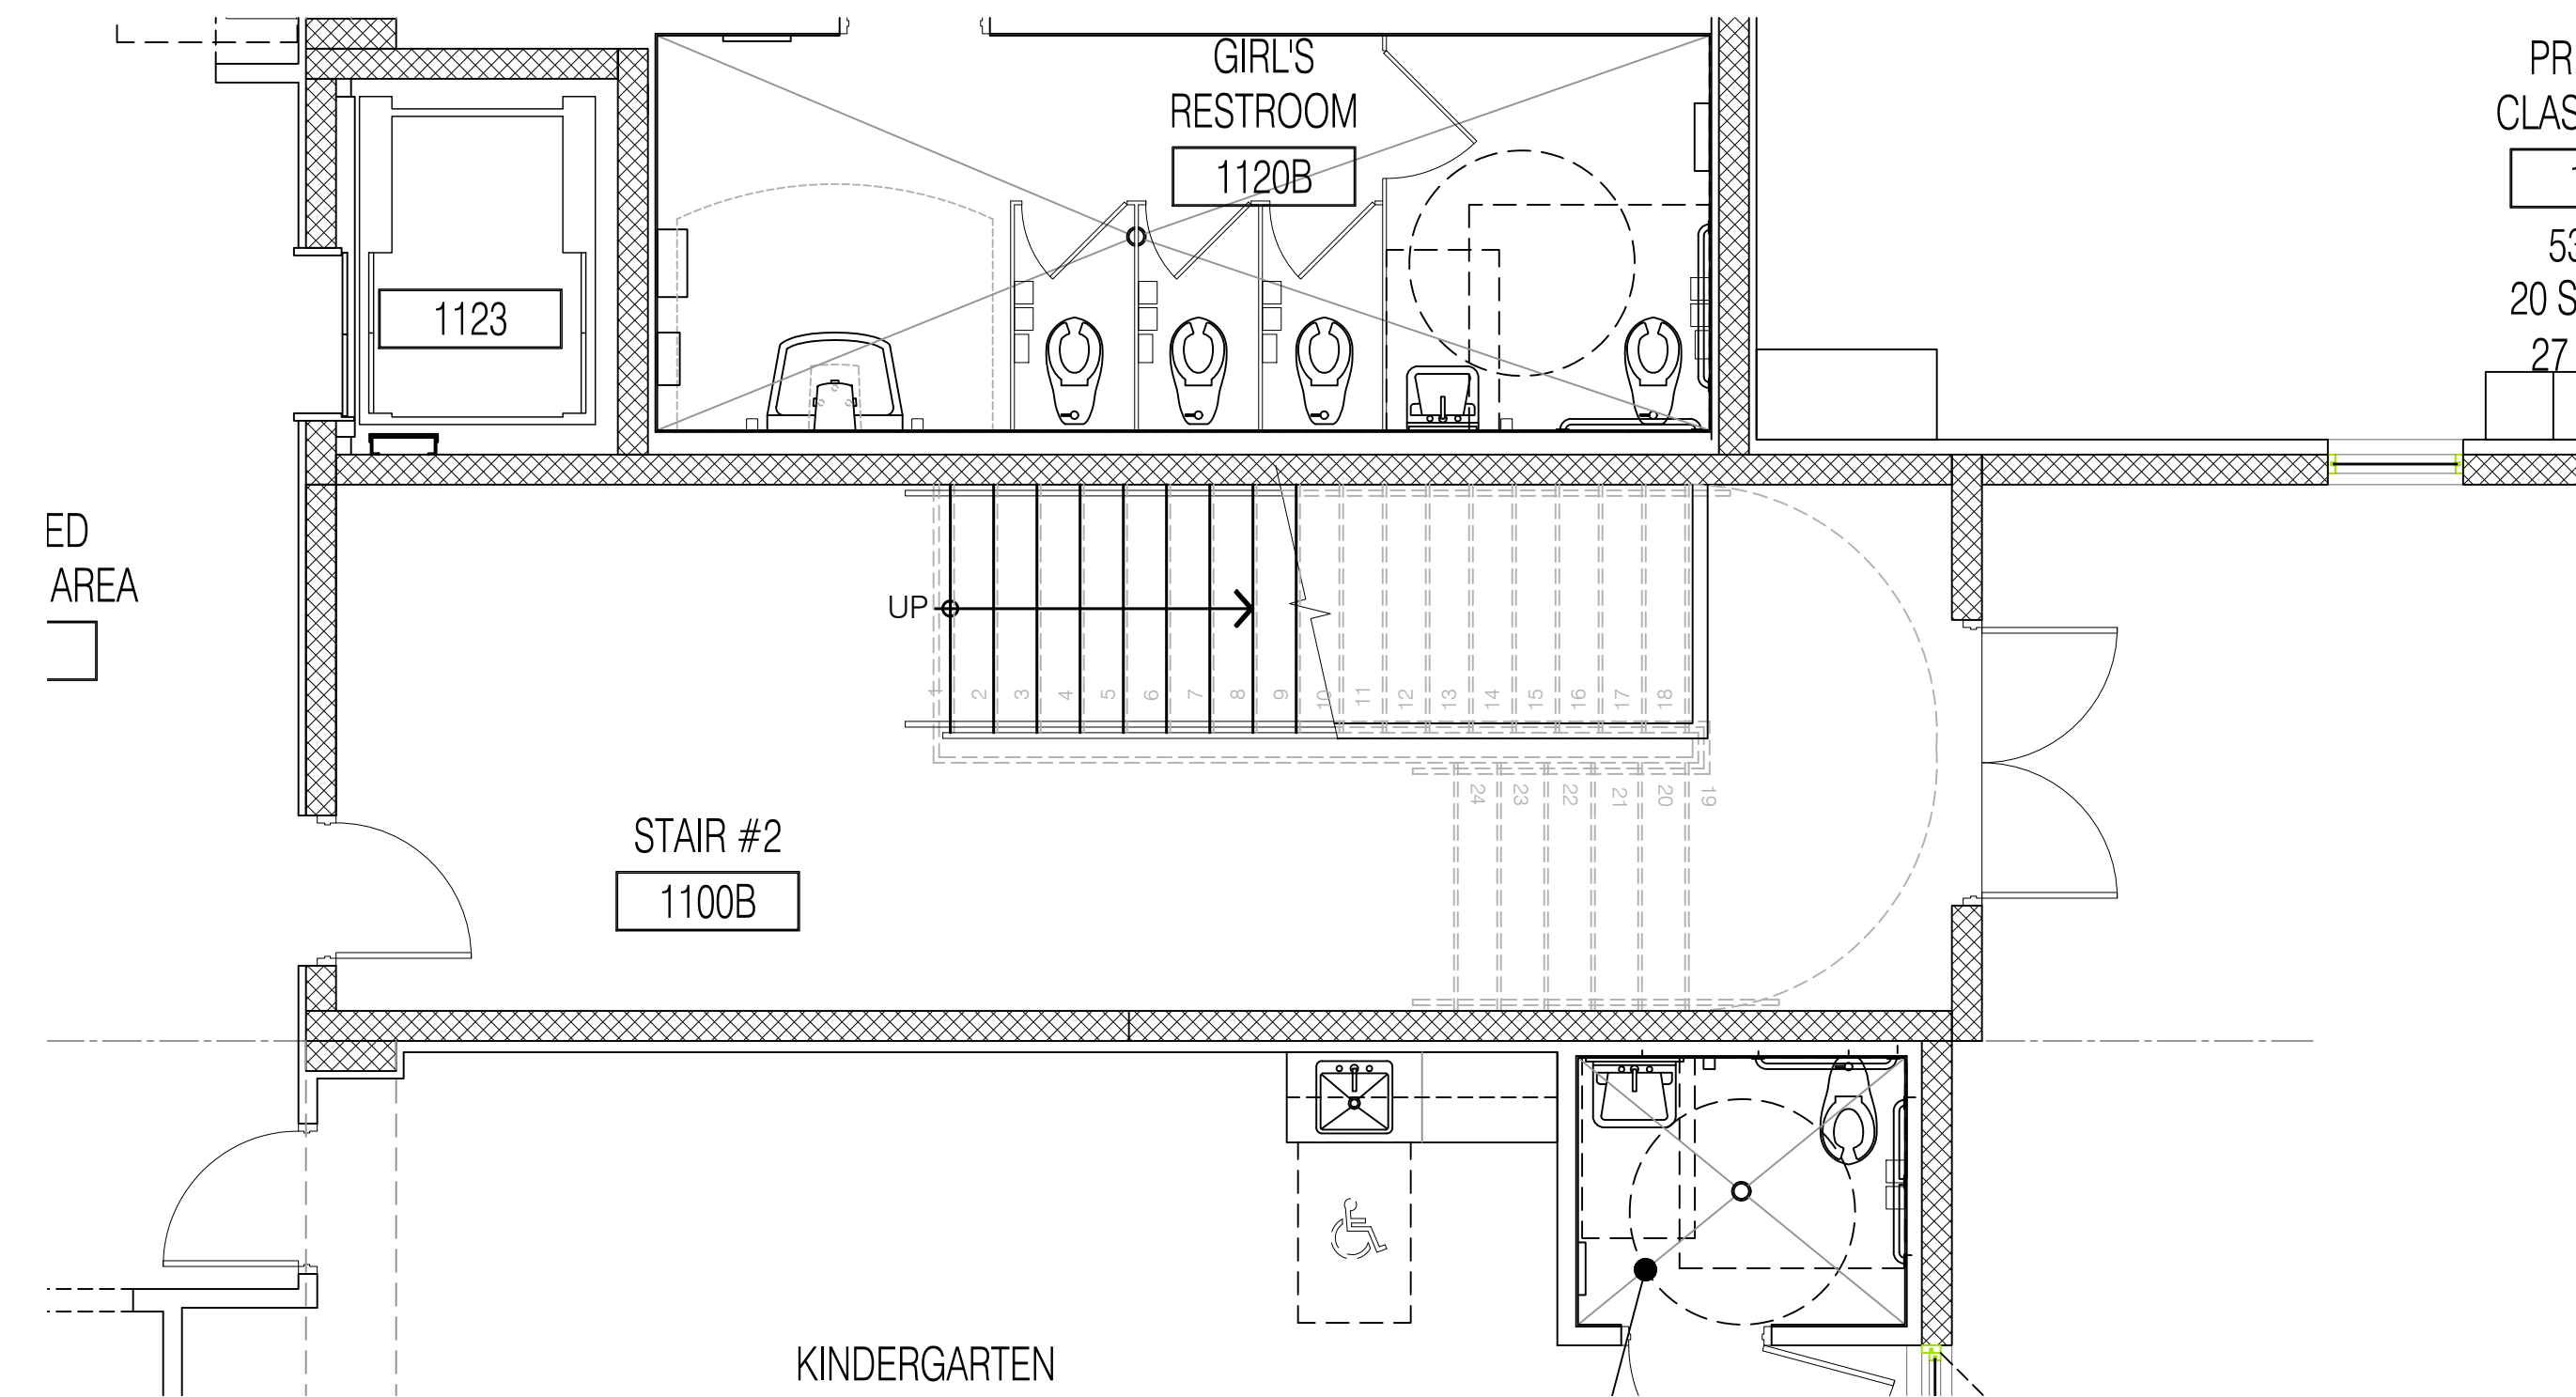


1 ENLARGED STAIR #2 PLAN - GROUND FLOOR
A-631 SCALE: 1/4" = 1'-0"

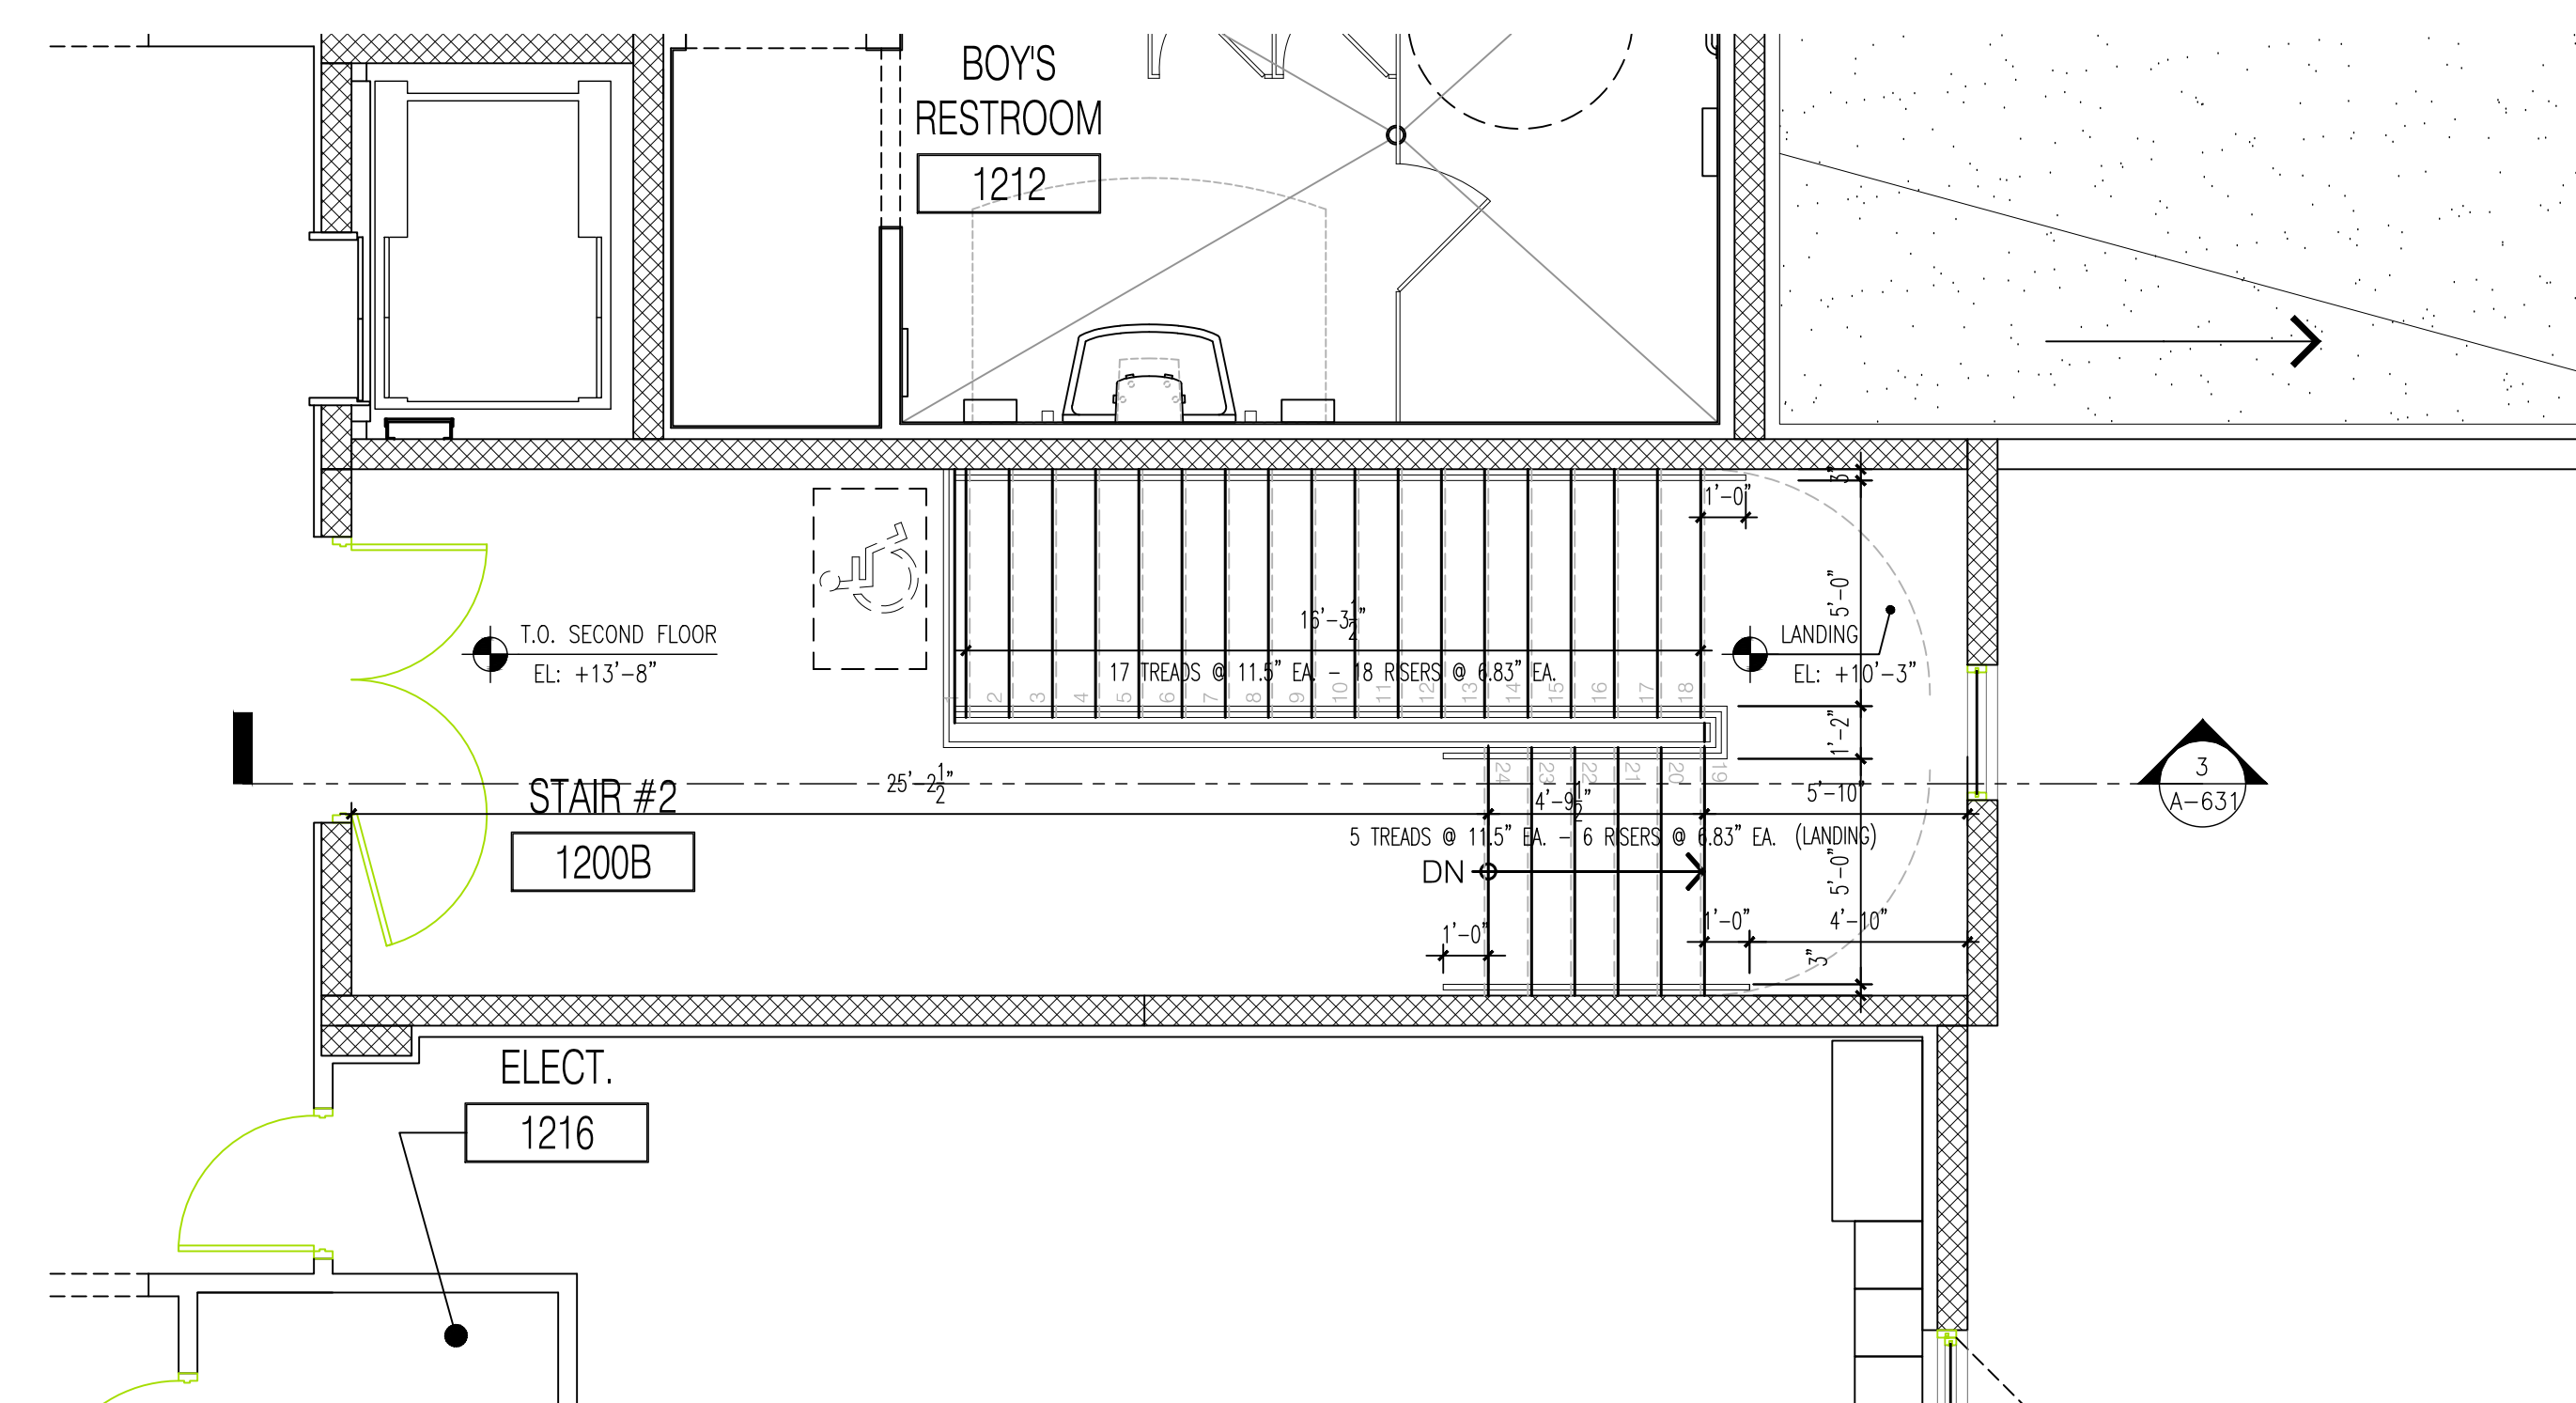


2 ENLARGED STAIR #2 PLAN - SECOND FLOOR
A-631 SCALE: 1/4" = 1'-0"

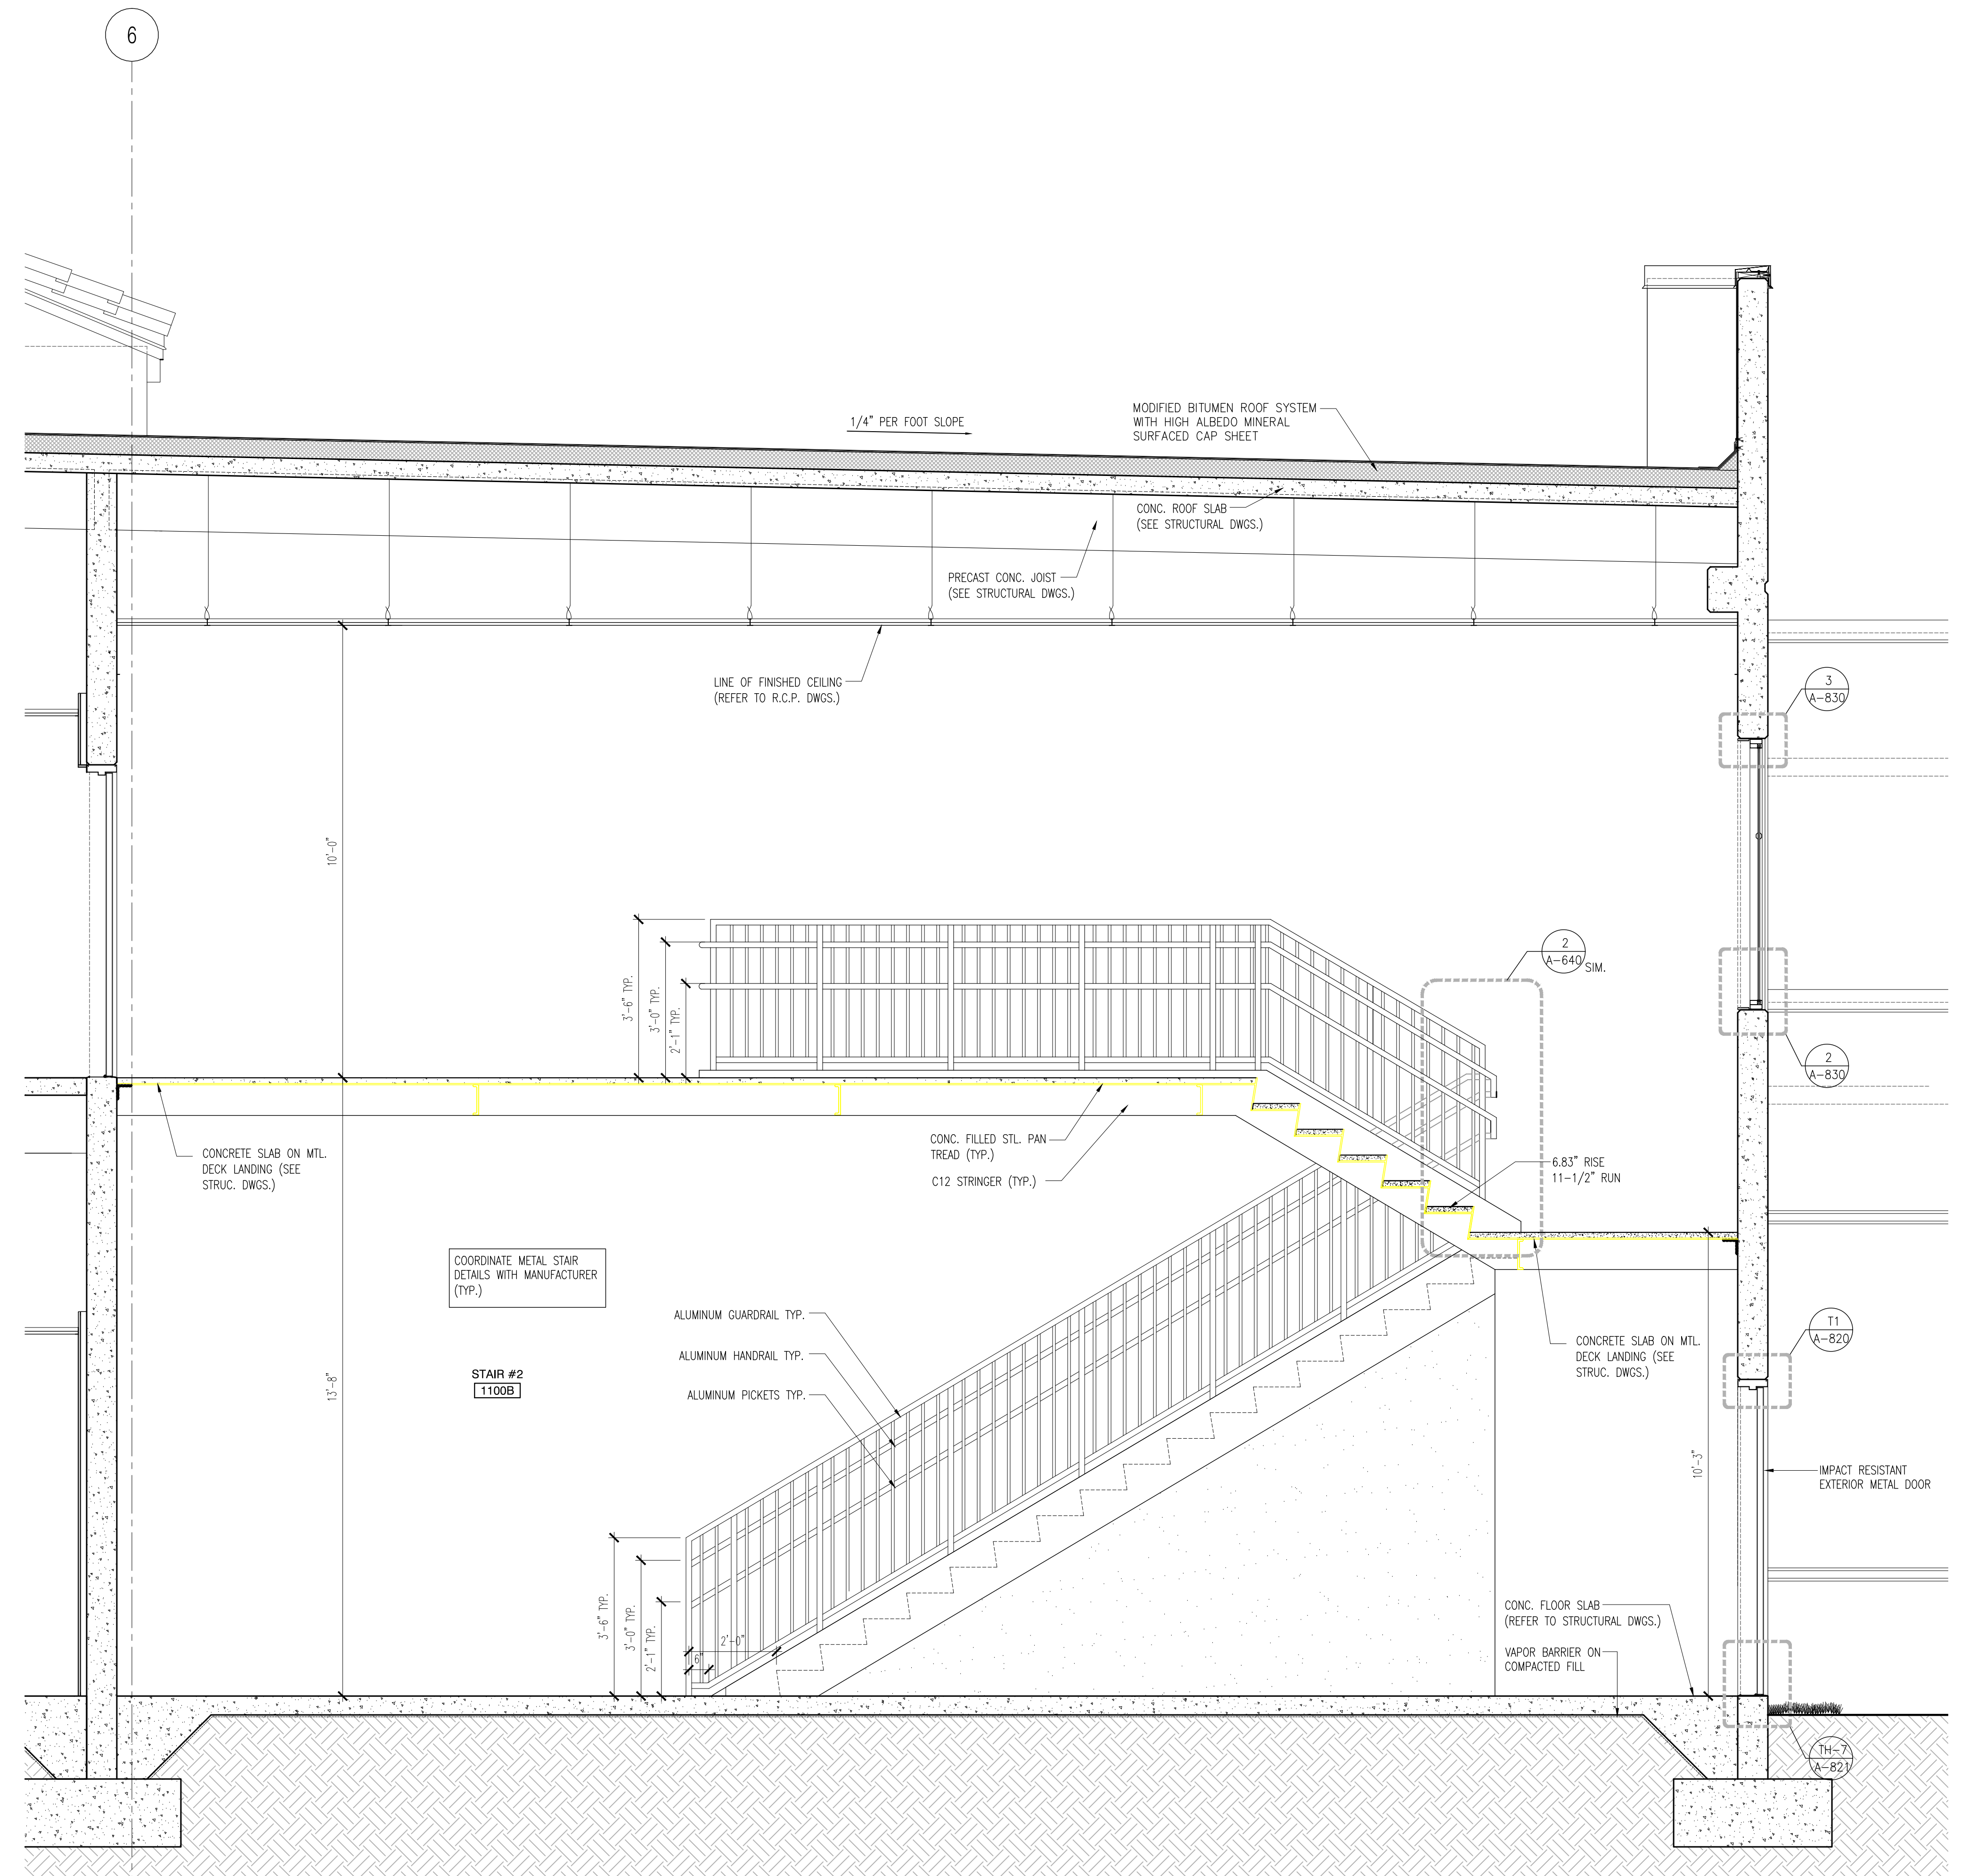


3 STAIR SECTION
A-631 SCALE: 1/2" = 1'-0"

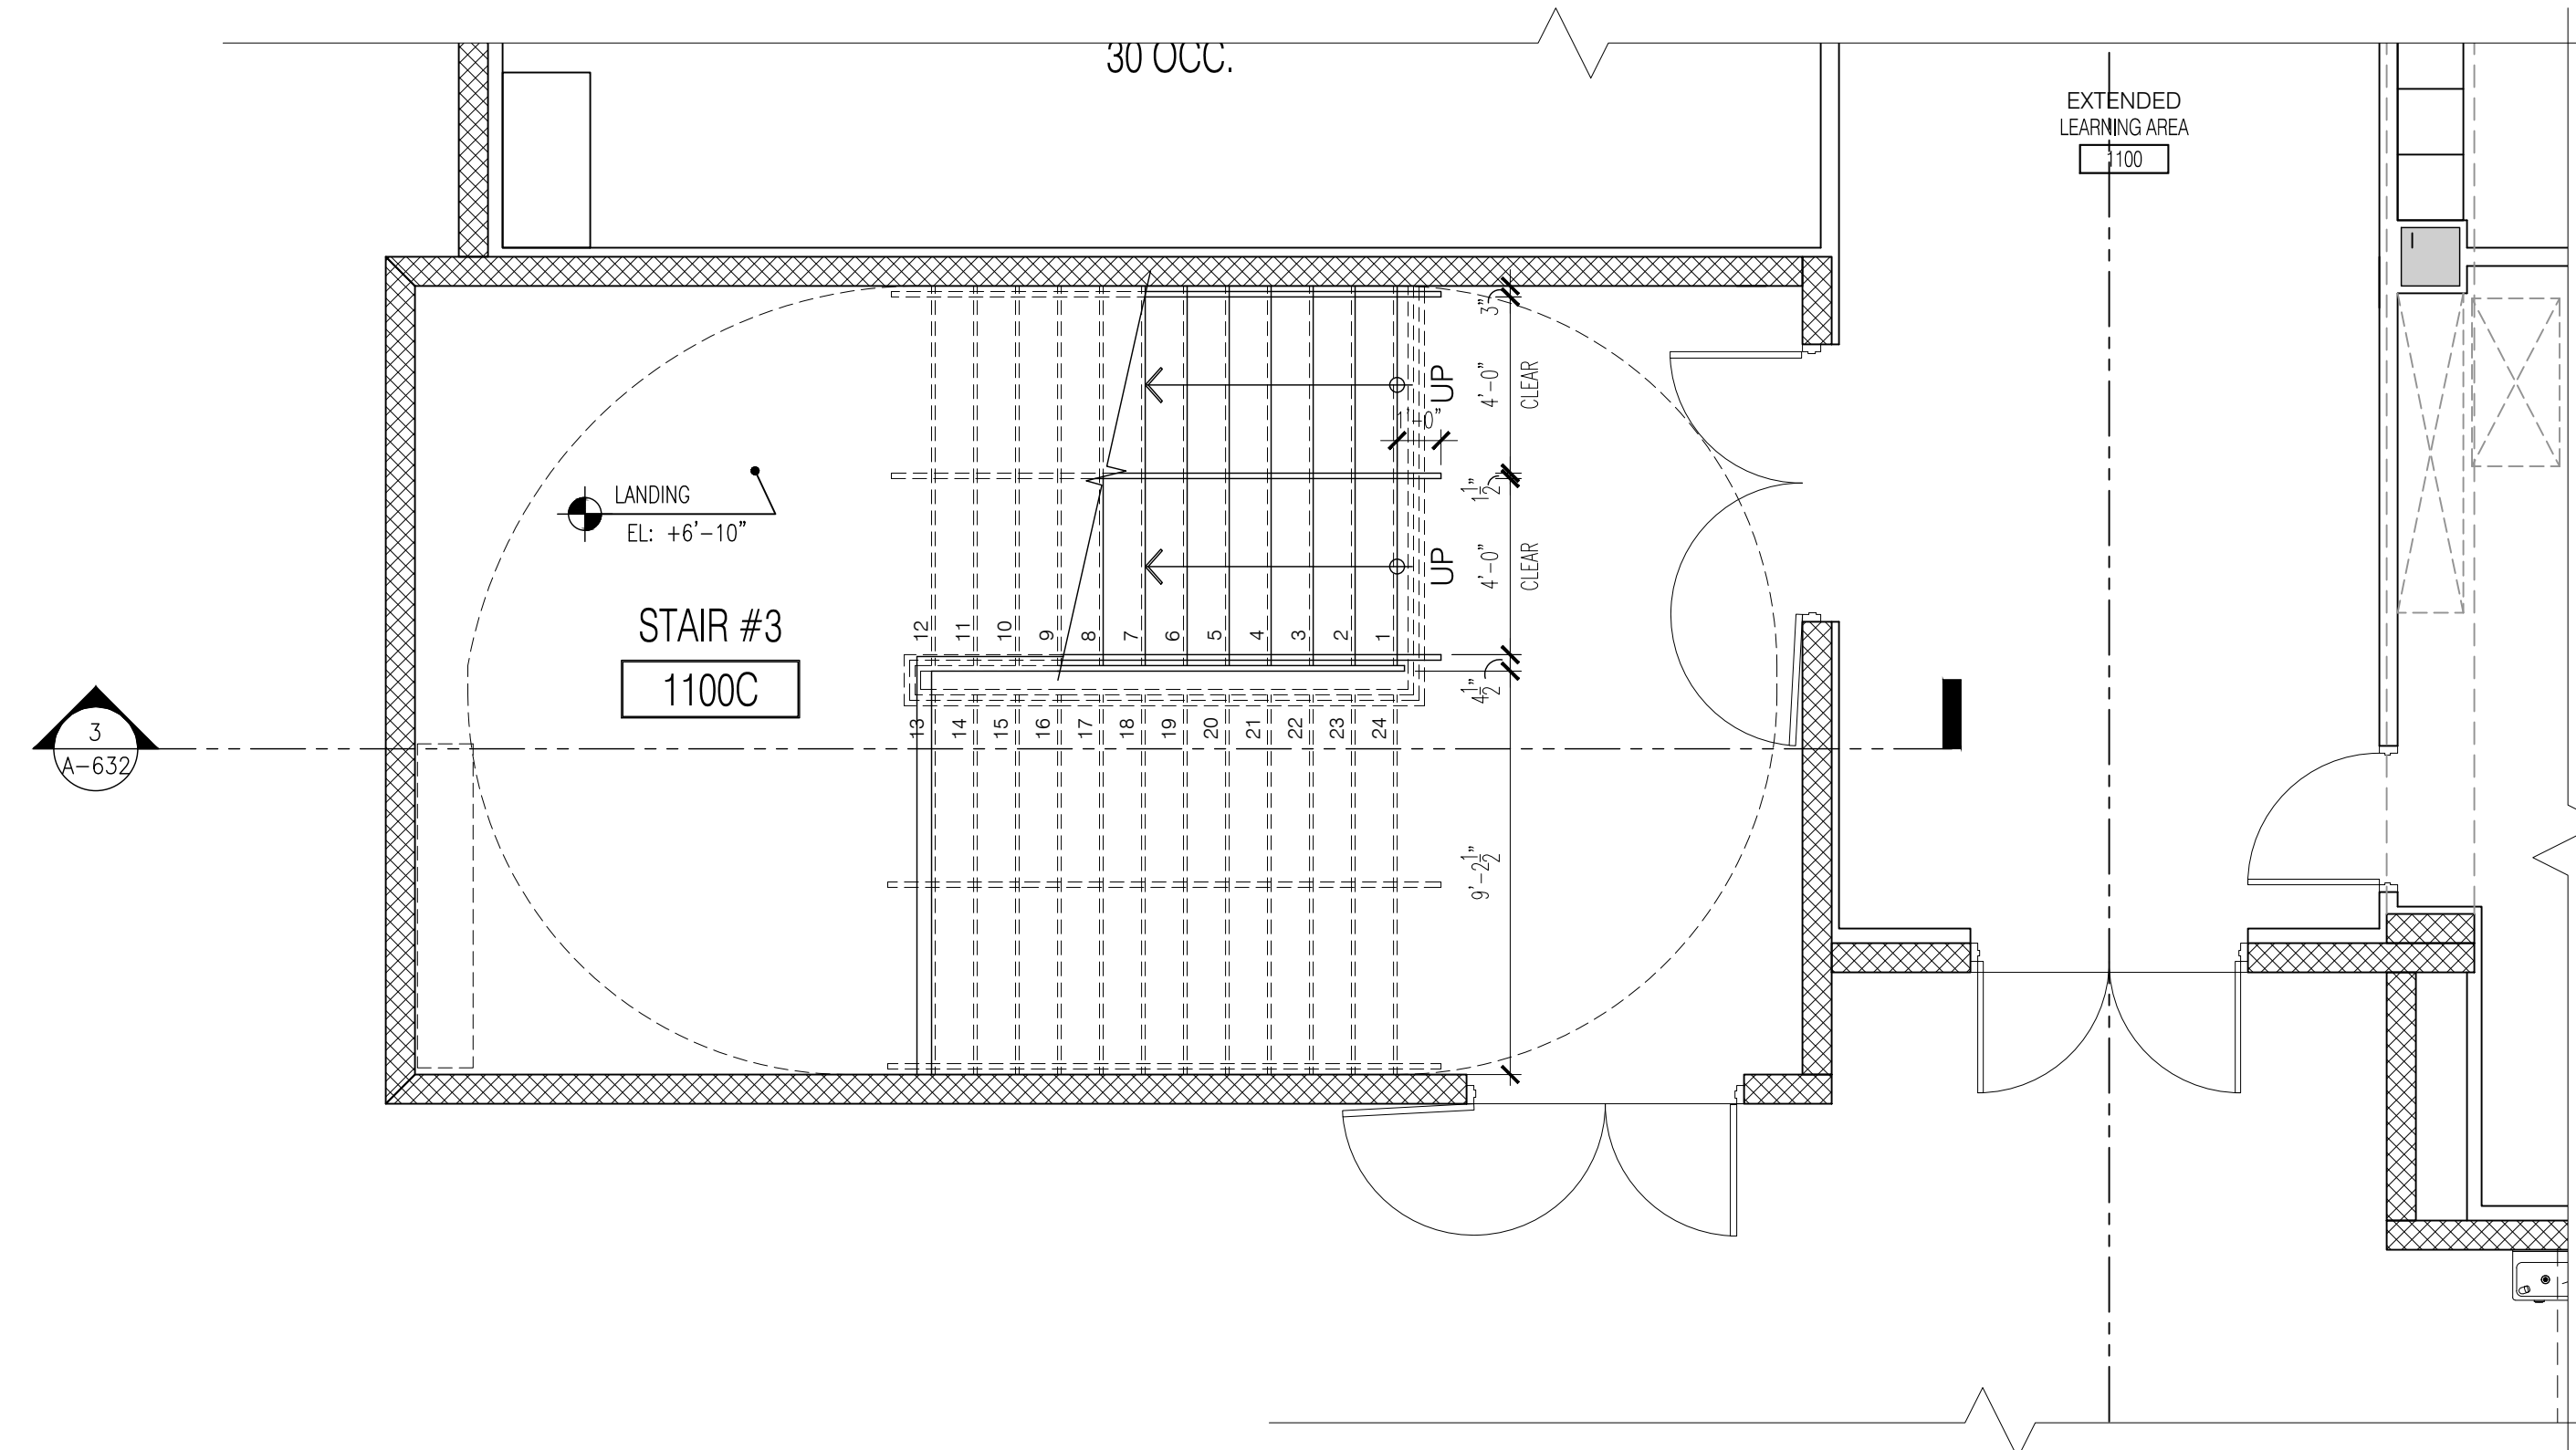


1 ENLARGED STAIR #3 PLAN - GROUND FLOOR
A-632 SCALE: 1/4" = 1'-0"

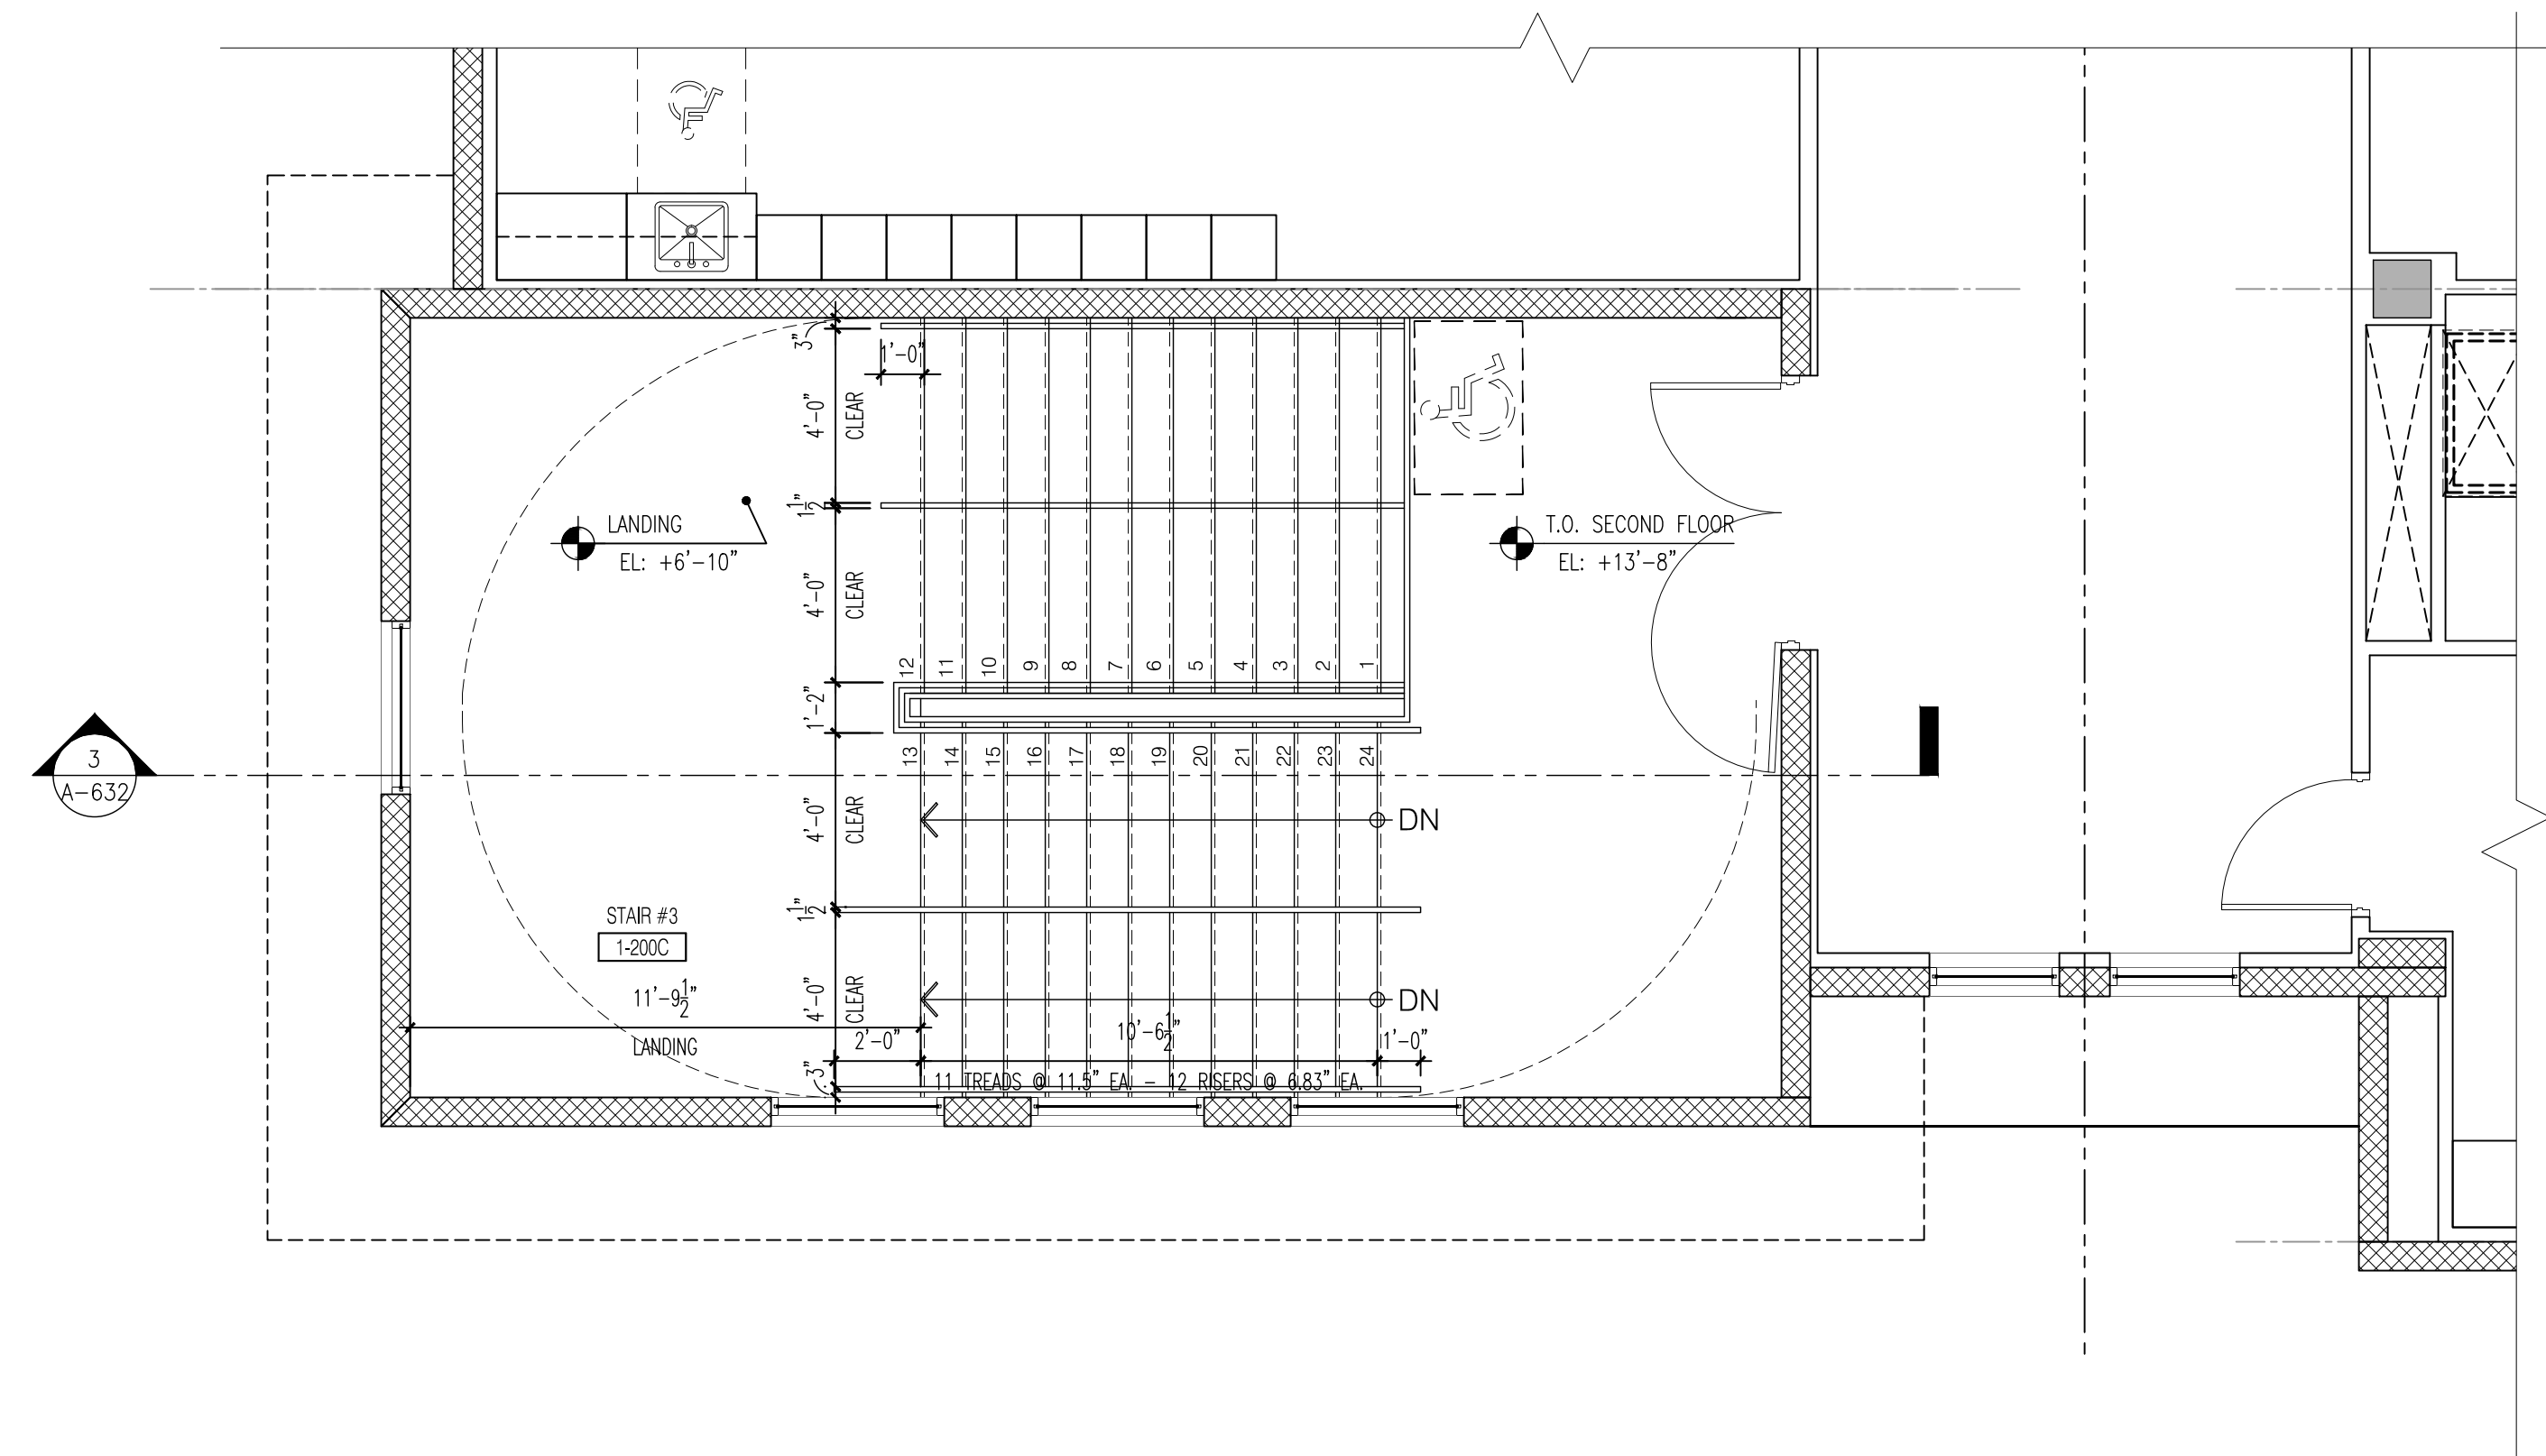


2 ENLARGED STAIR #3 PLAN - SECOND FLOOR
A-632 SCALE: 1/4" = 1'-0"

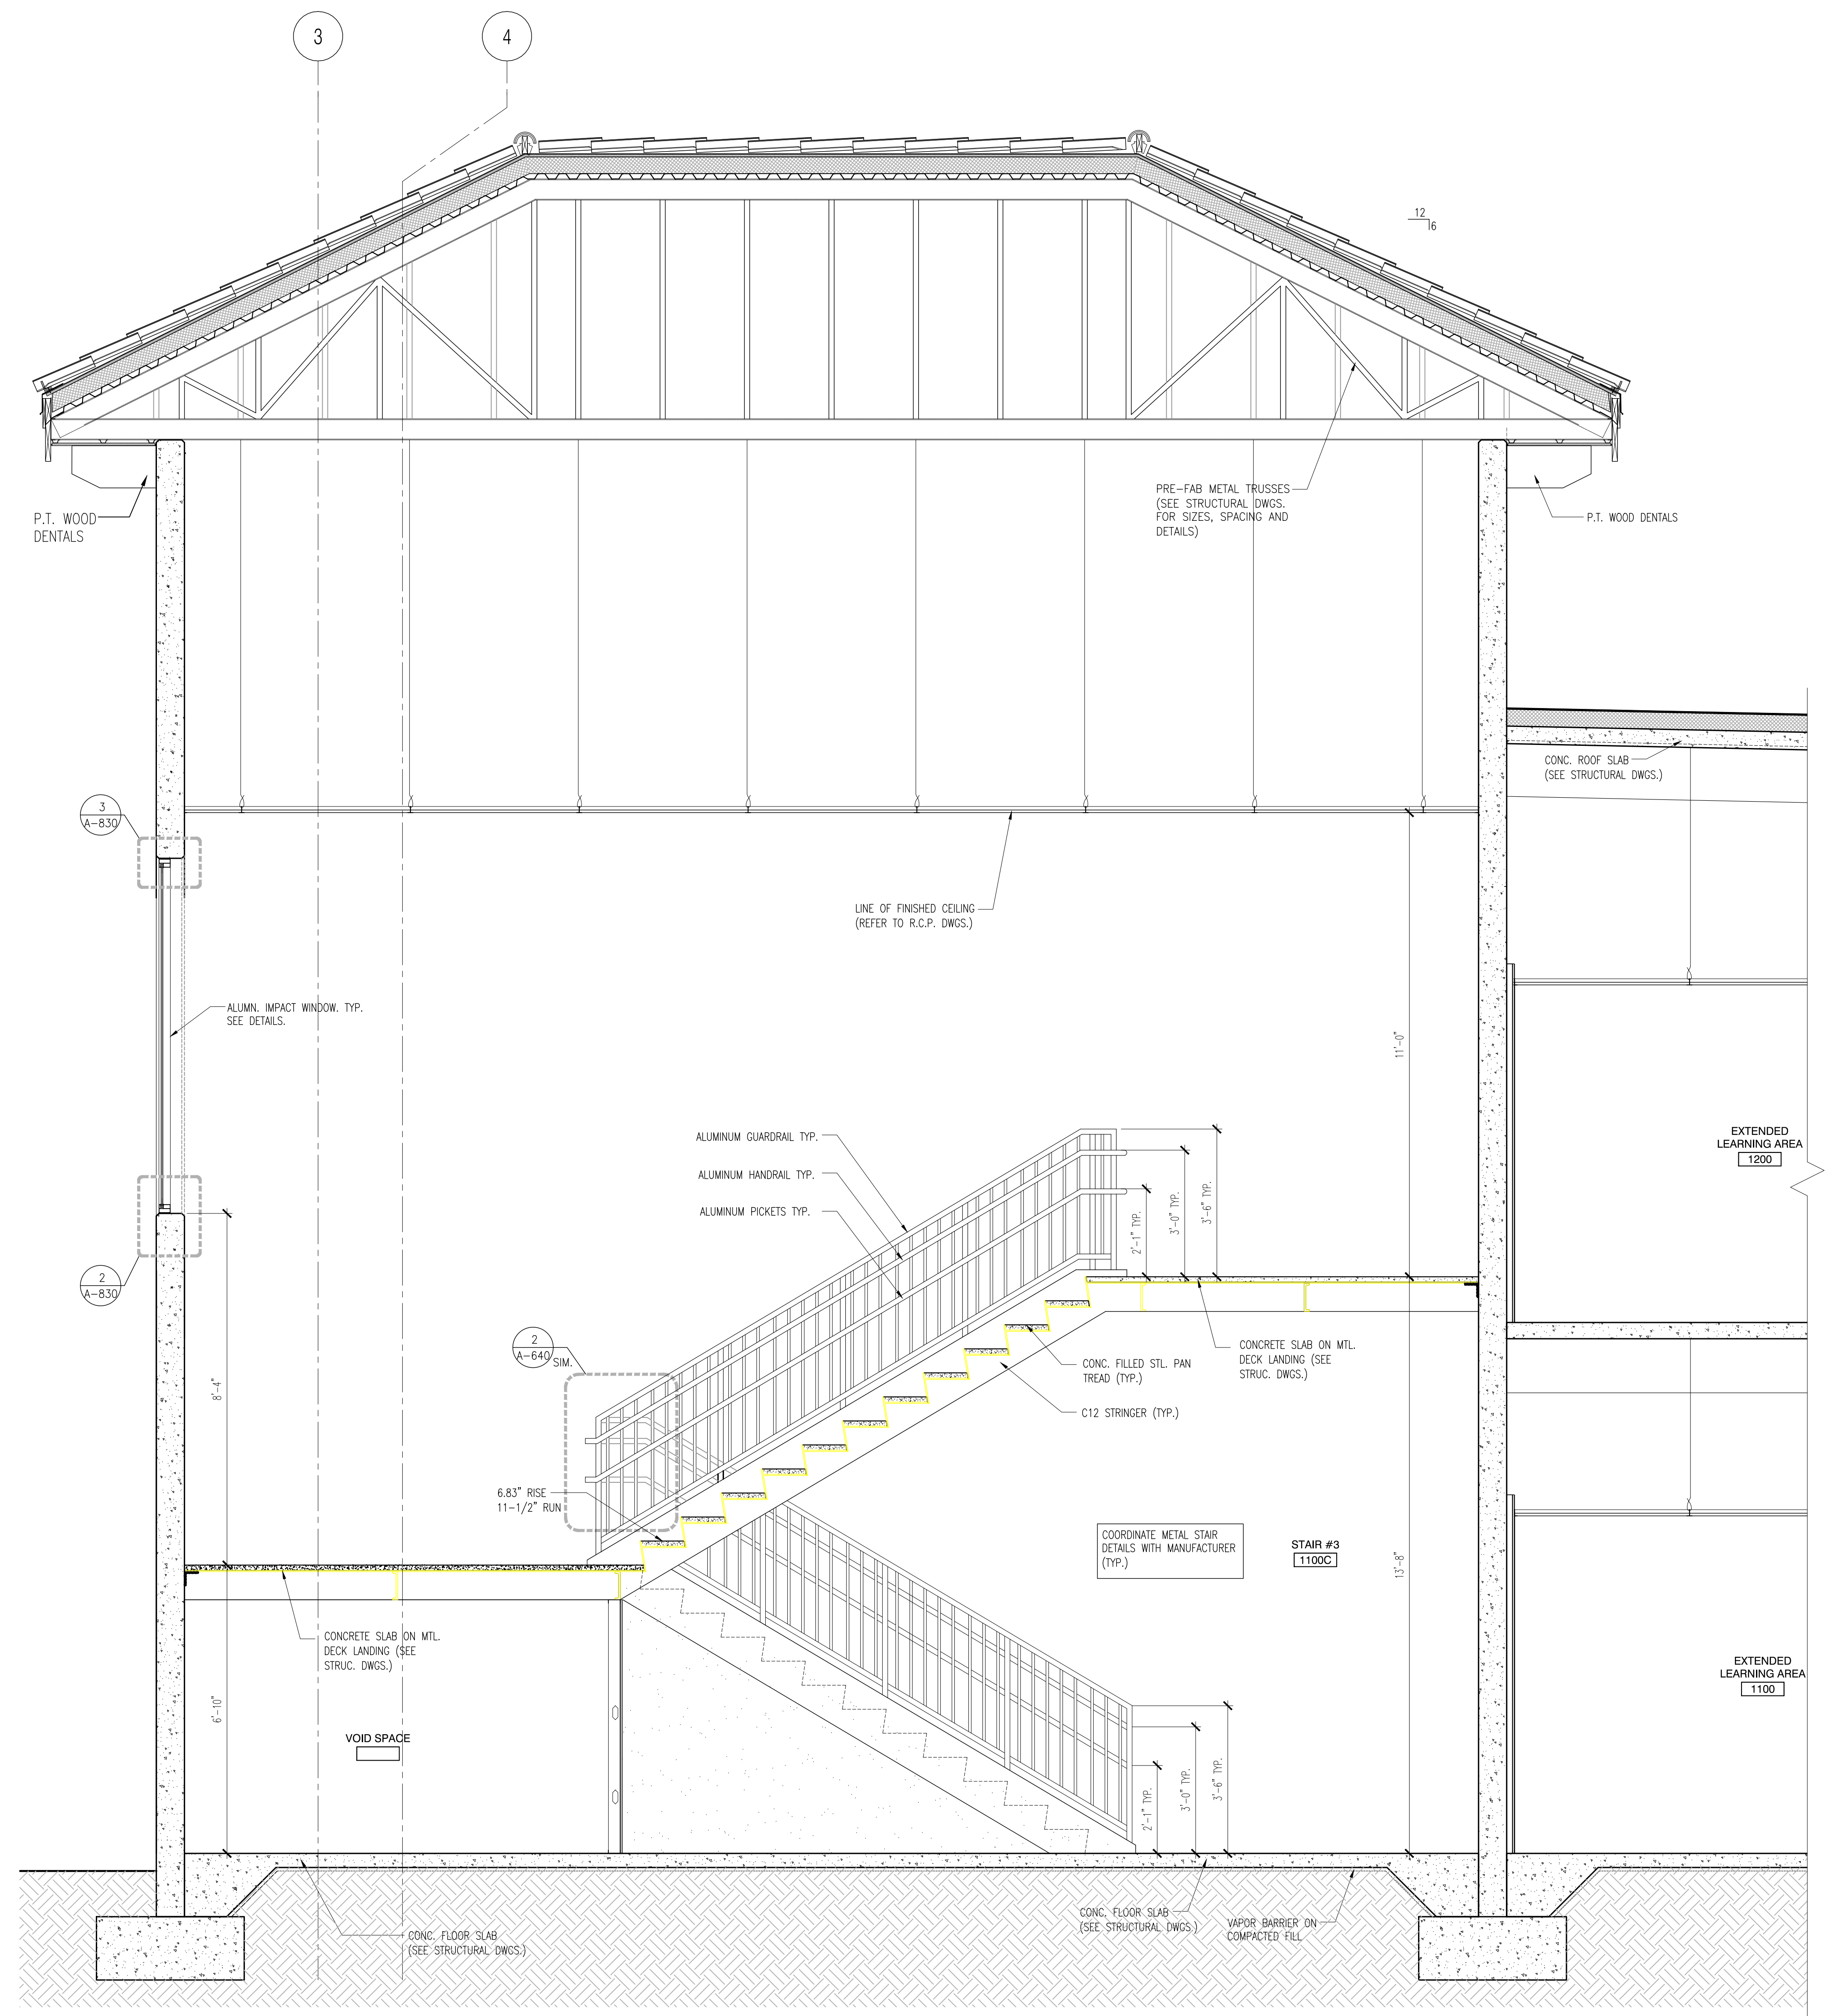


3 STAIR SECTION
A-632 SCALE: 1/2" = 1'-0"

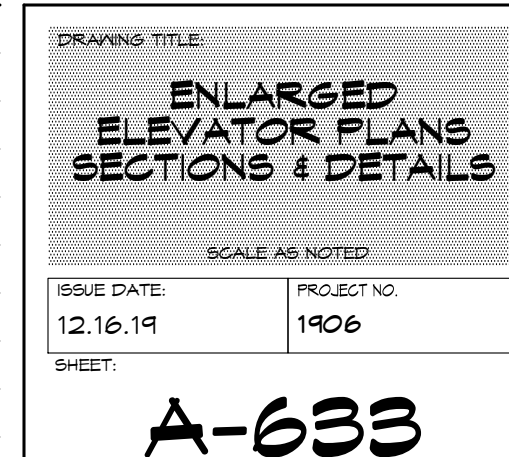


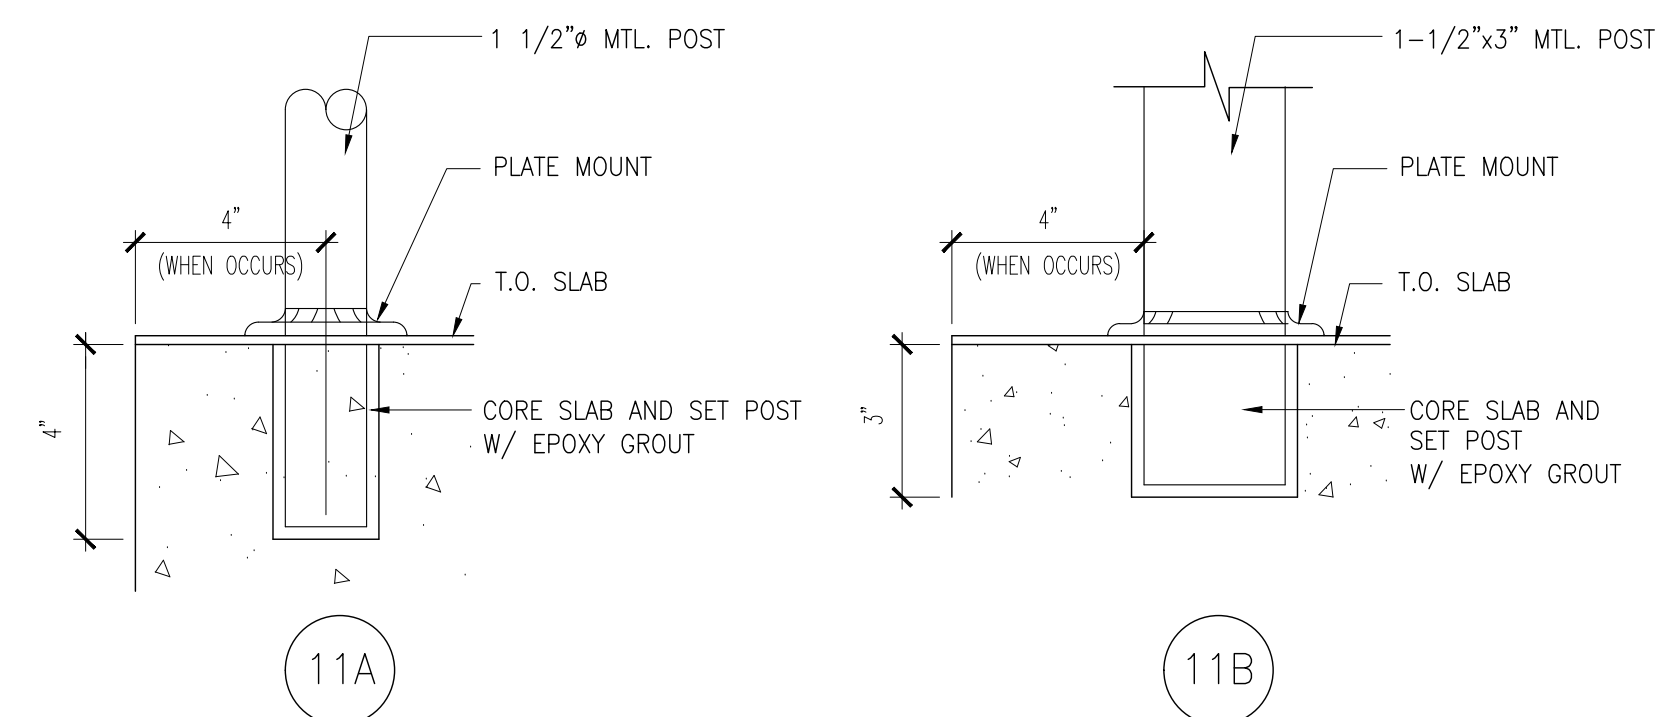


11 SLAB CORE CUT @ RAILING
A-640 SCALE: 3" = 1'-0"

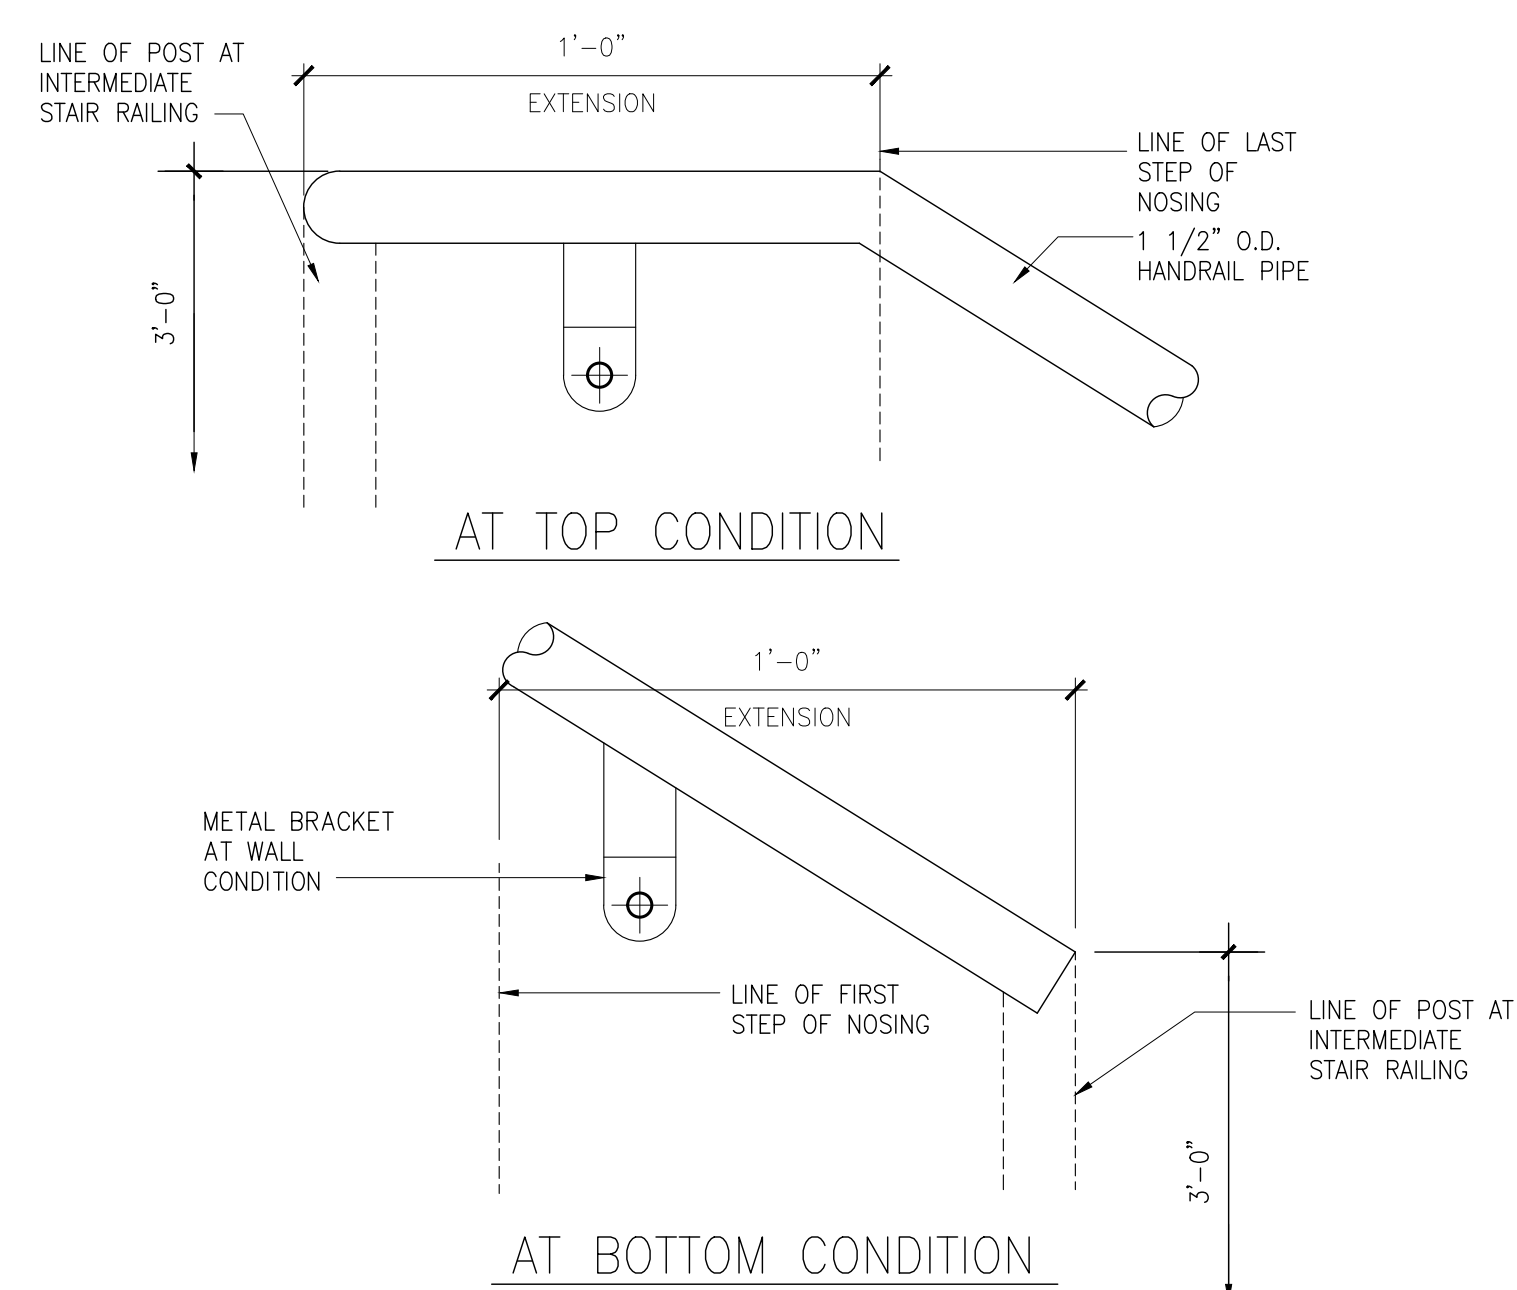


10 HANDRAIL DETAIL
A-640 SCALE: 3" = 1'-0"

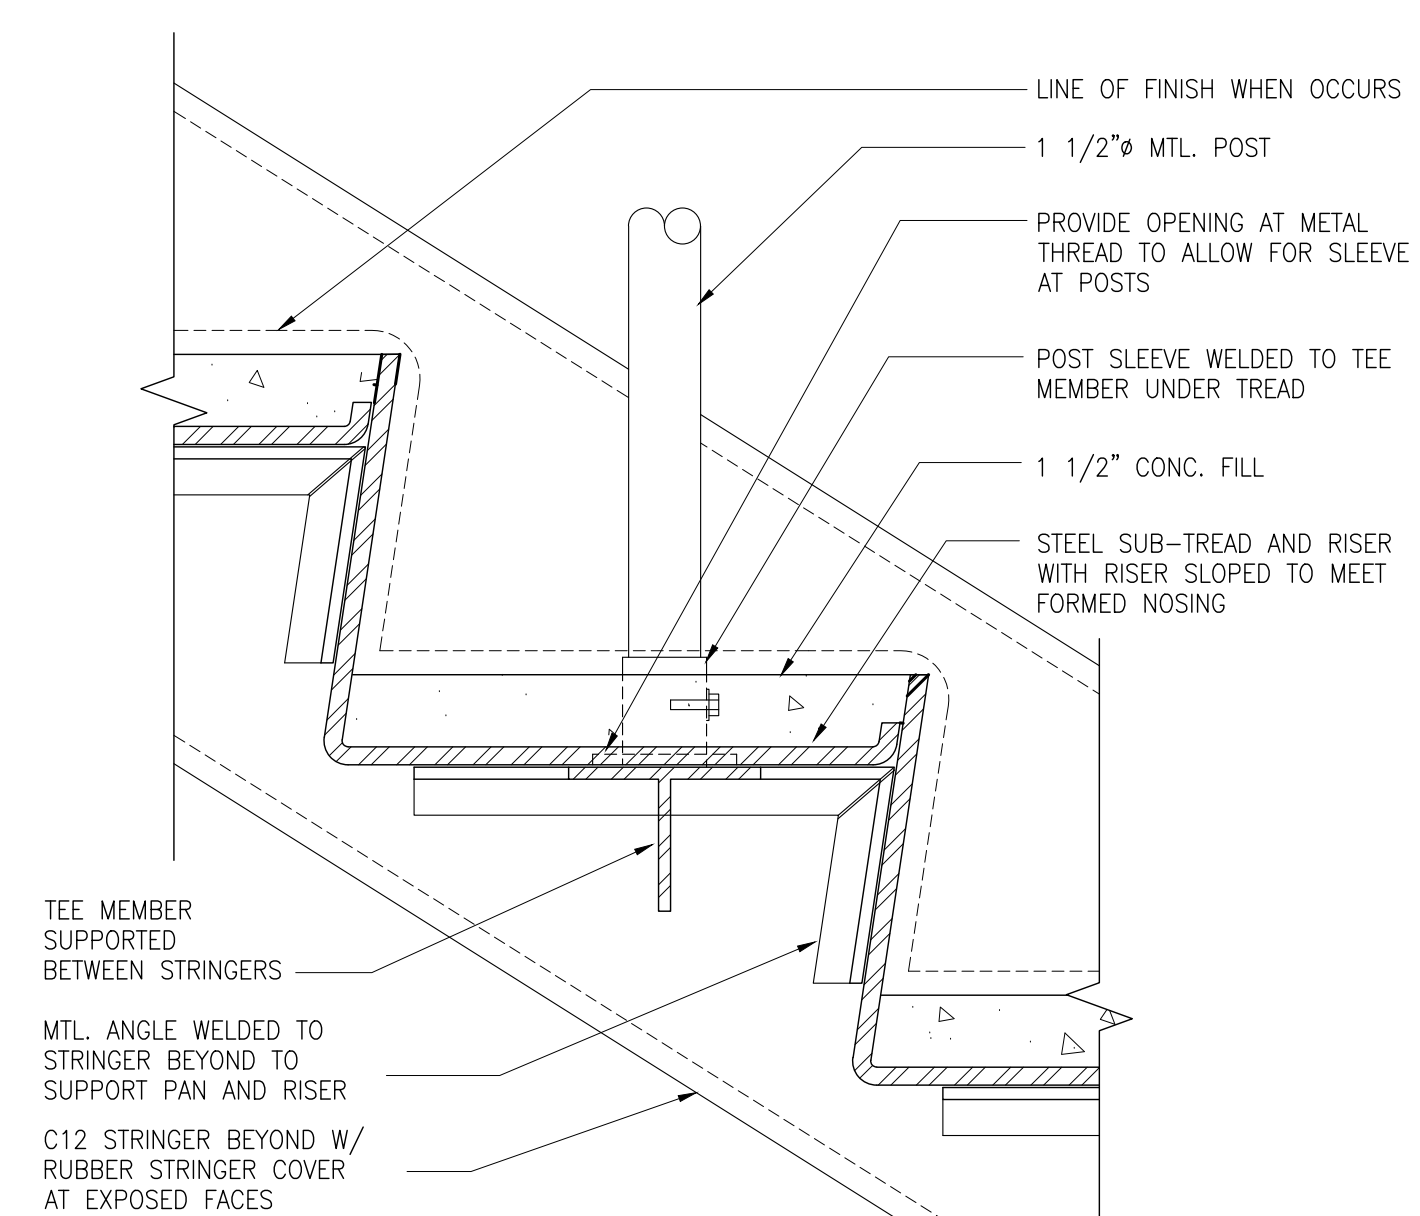


9 DETAIL @ METAL TREAD
A-640 SCALE: 3" = 1'-0"

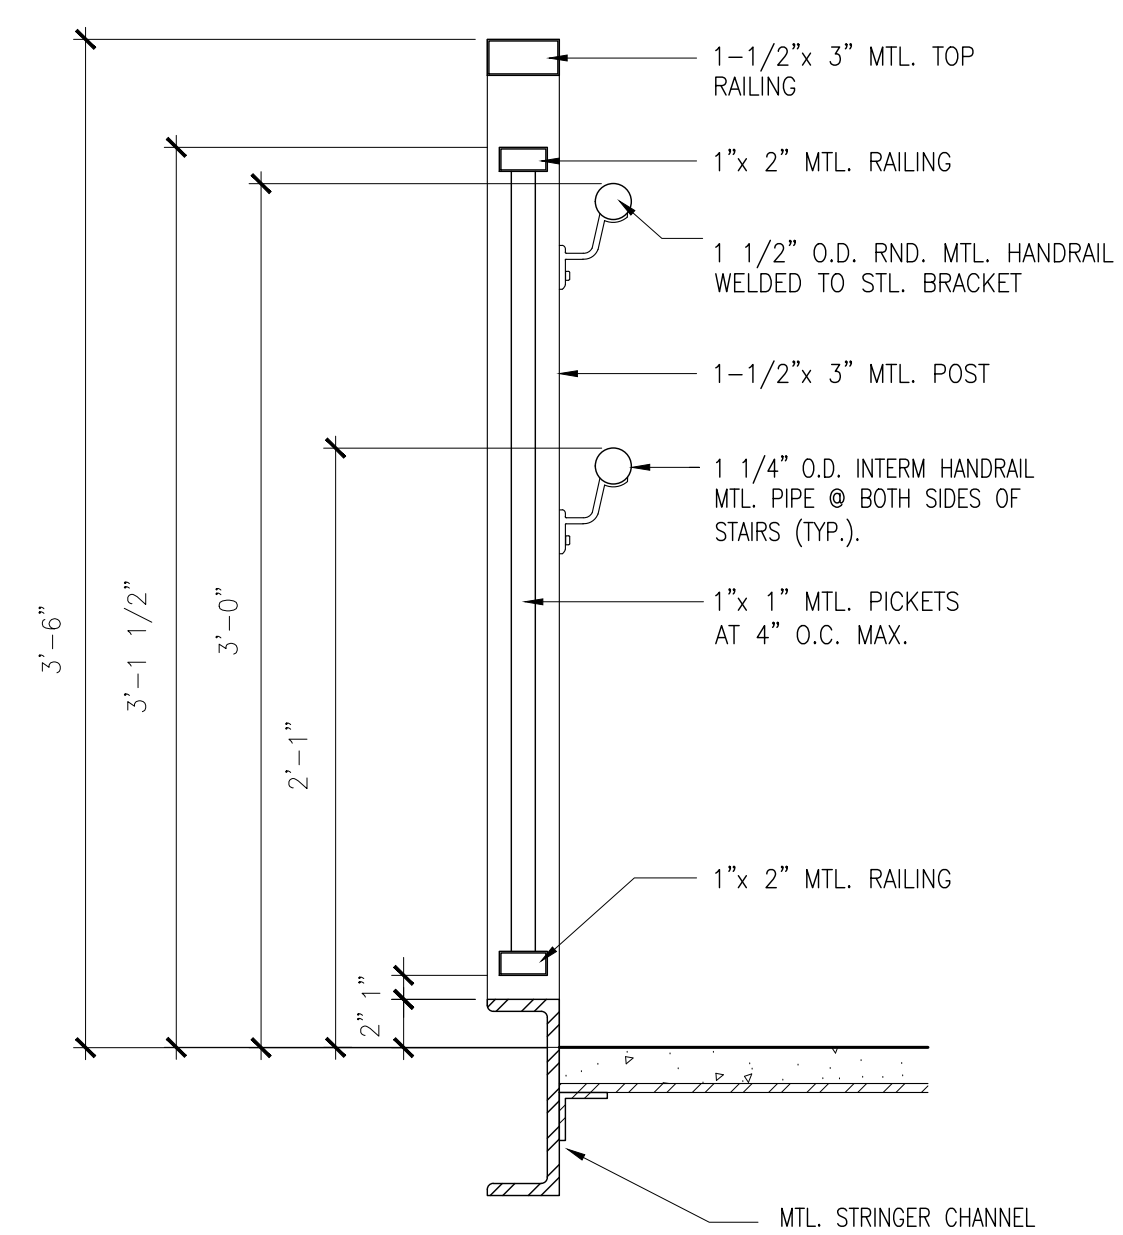


8 RAILING DETAIL @ MTL. STAIRS
A-640 SCALE: 1-1/2" = 1'-0"

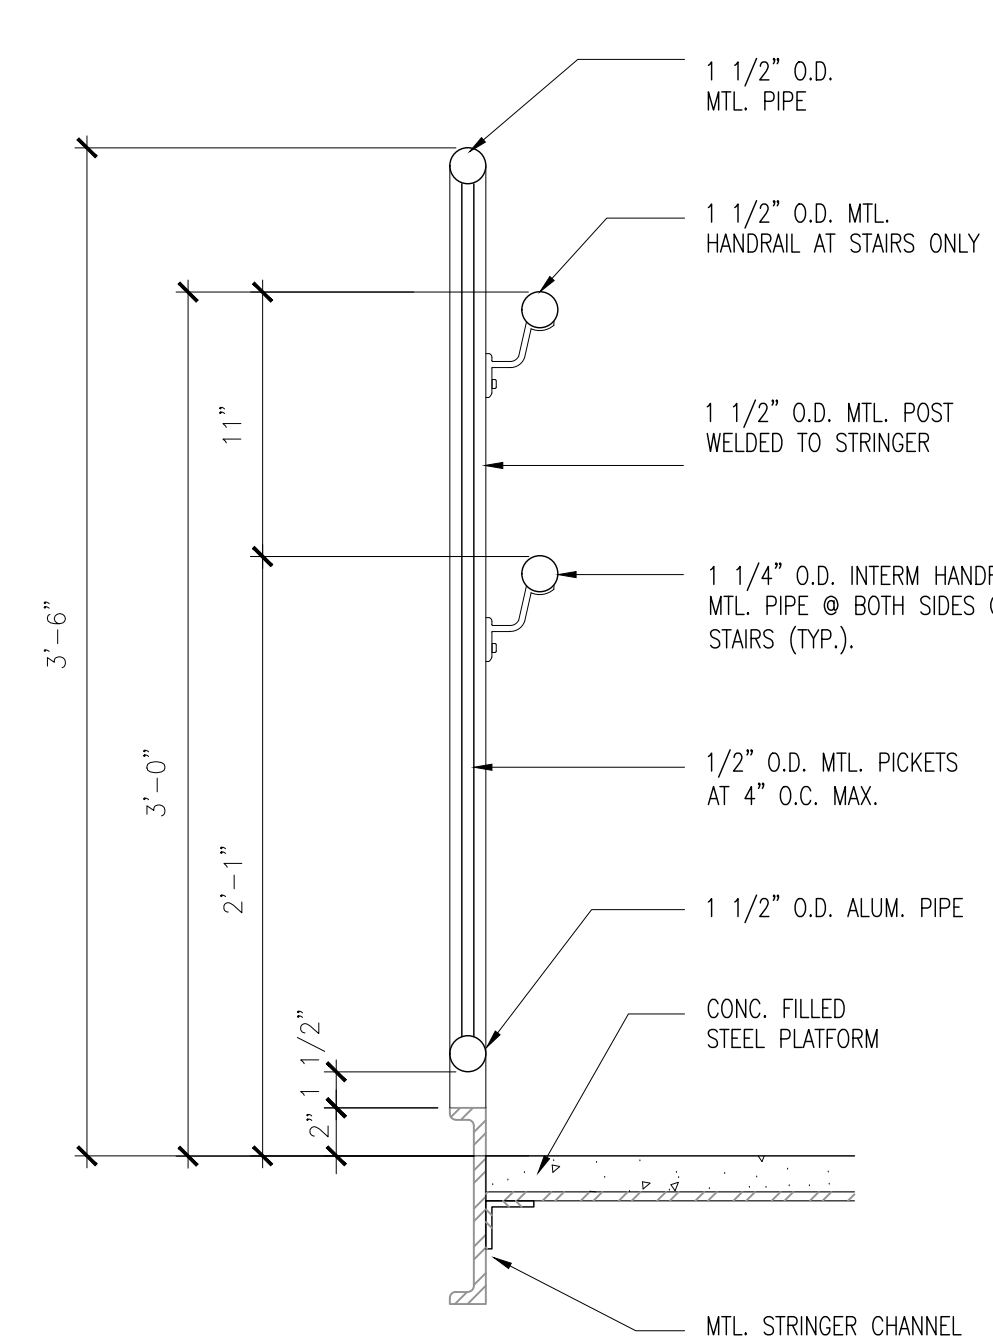


7 RAILING DETAIL @ MTL. STAIRS, TYP.
A-640 SCALE: 1-1/2" = 1'-0"

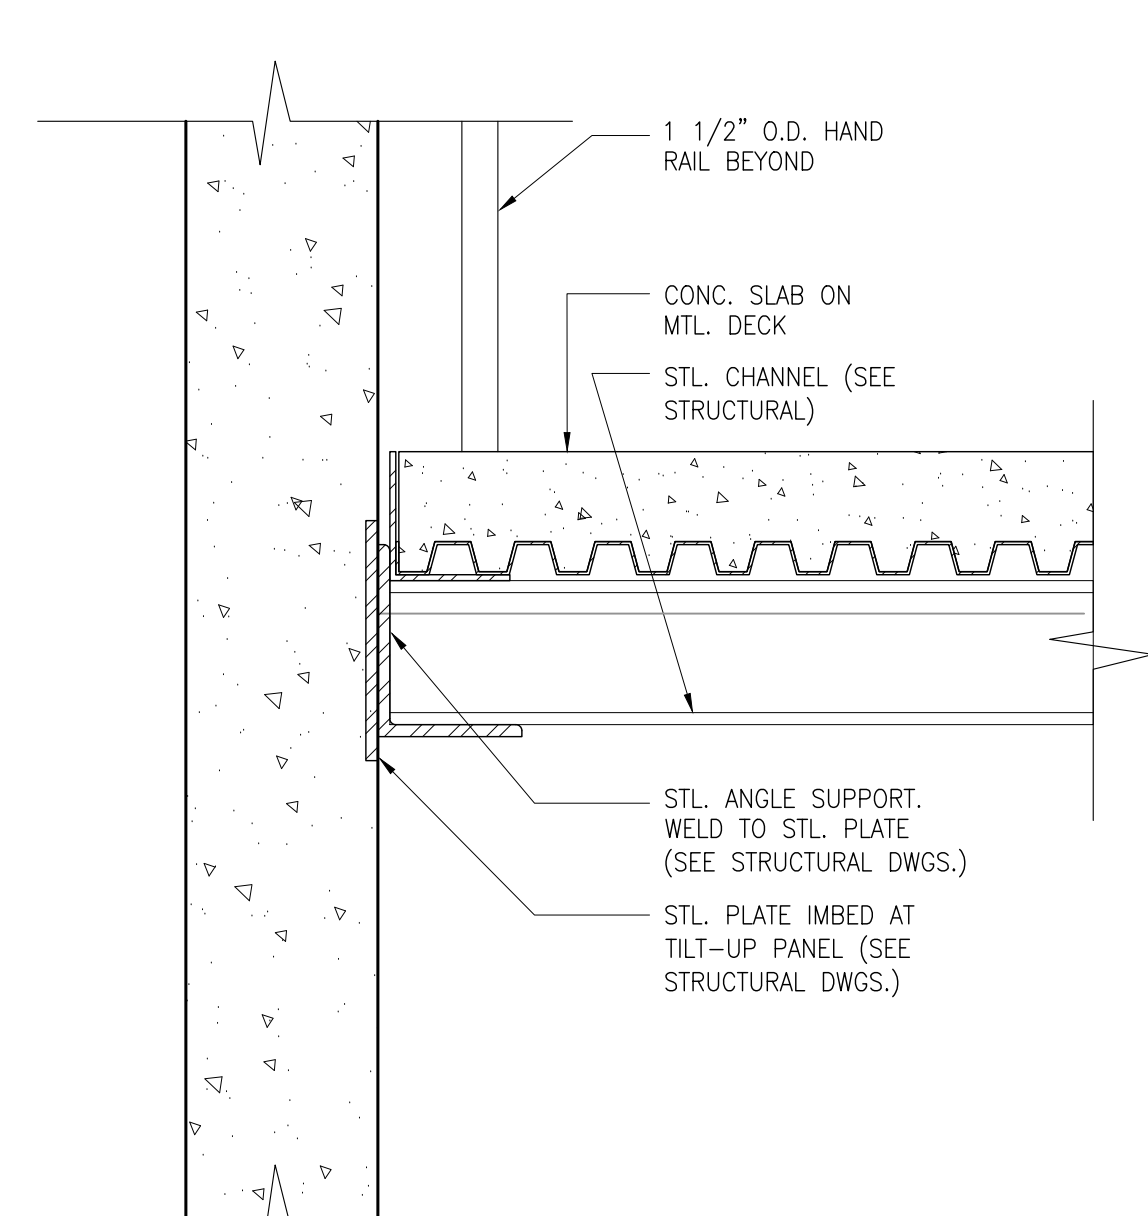


6 STAIR PAN MTL. LANDING DETAIL
A-640 SCALE: 1-1/2" = 1'-0"

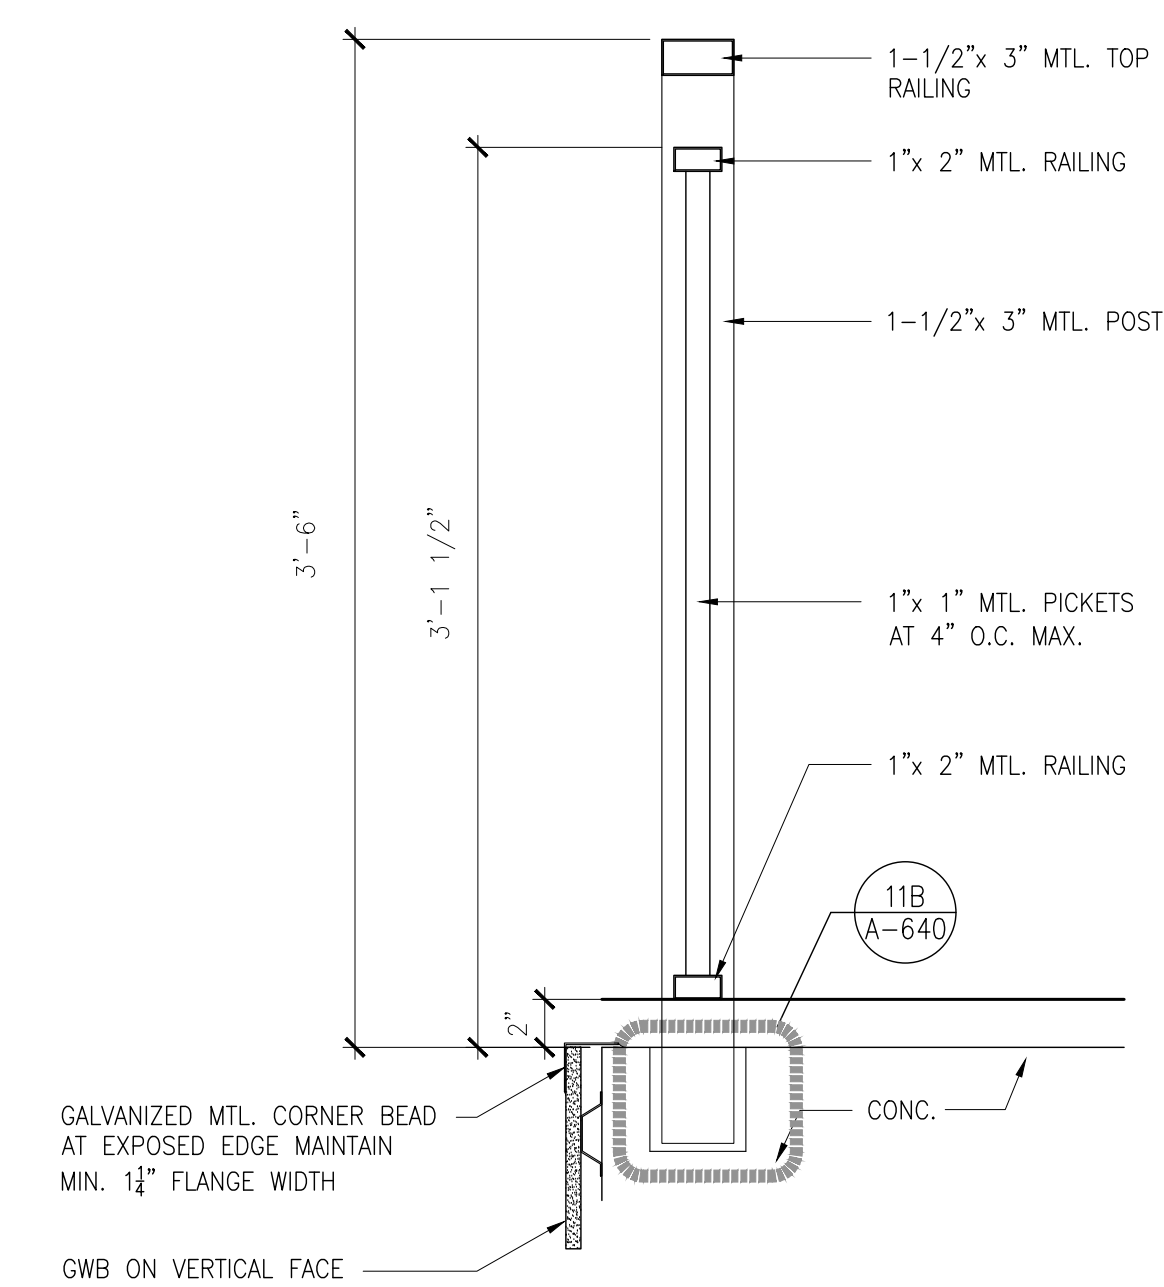


5 RAILING DETAIL @ CONC. SLAB
A-640 SCALE: 1" = 1'-0"

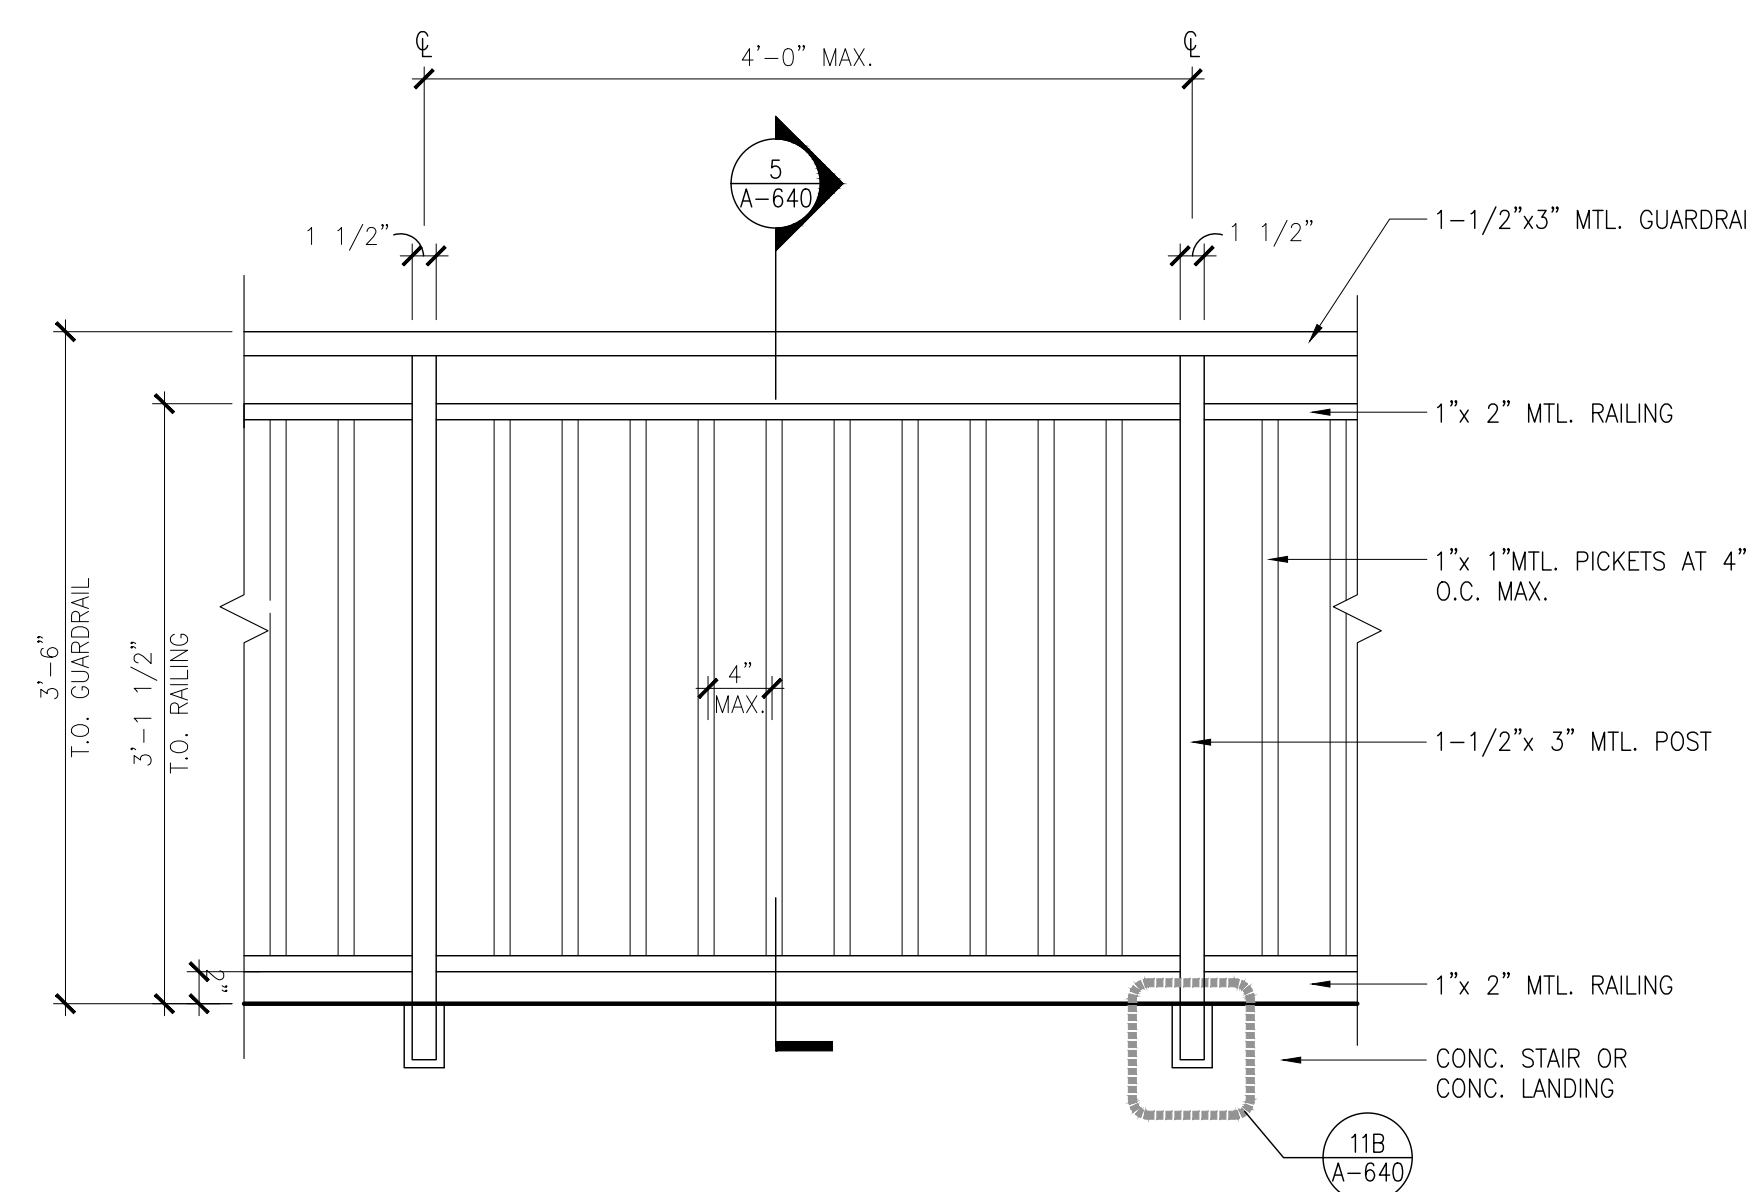


4 RAILING ELEVATION
A-640 SCALE: 1" = 1'-0"

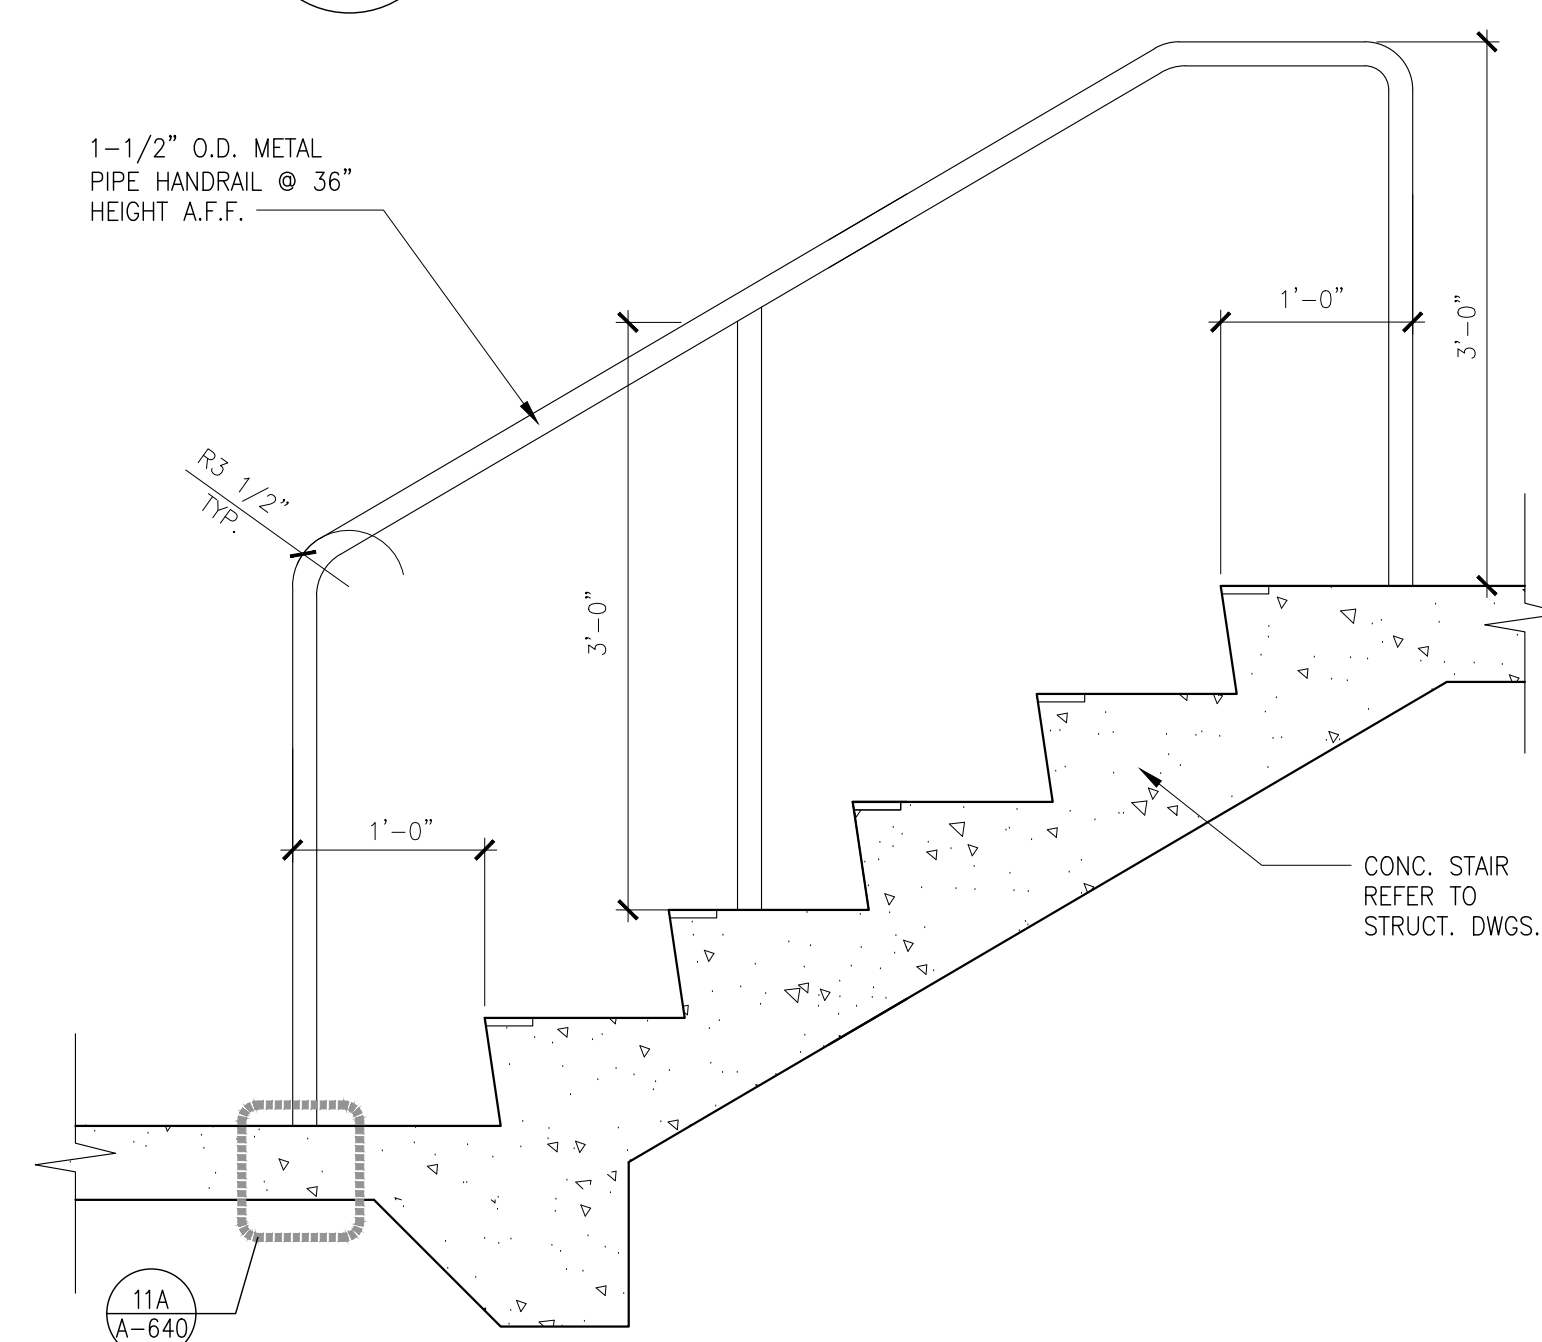

3 HANDRAIL DETAIL ON BOTTOM CONDITION @ CONC. STAIRS
A-640 SCALE: 1" = 1'-0"

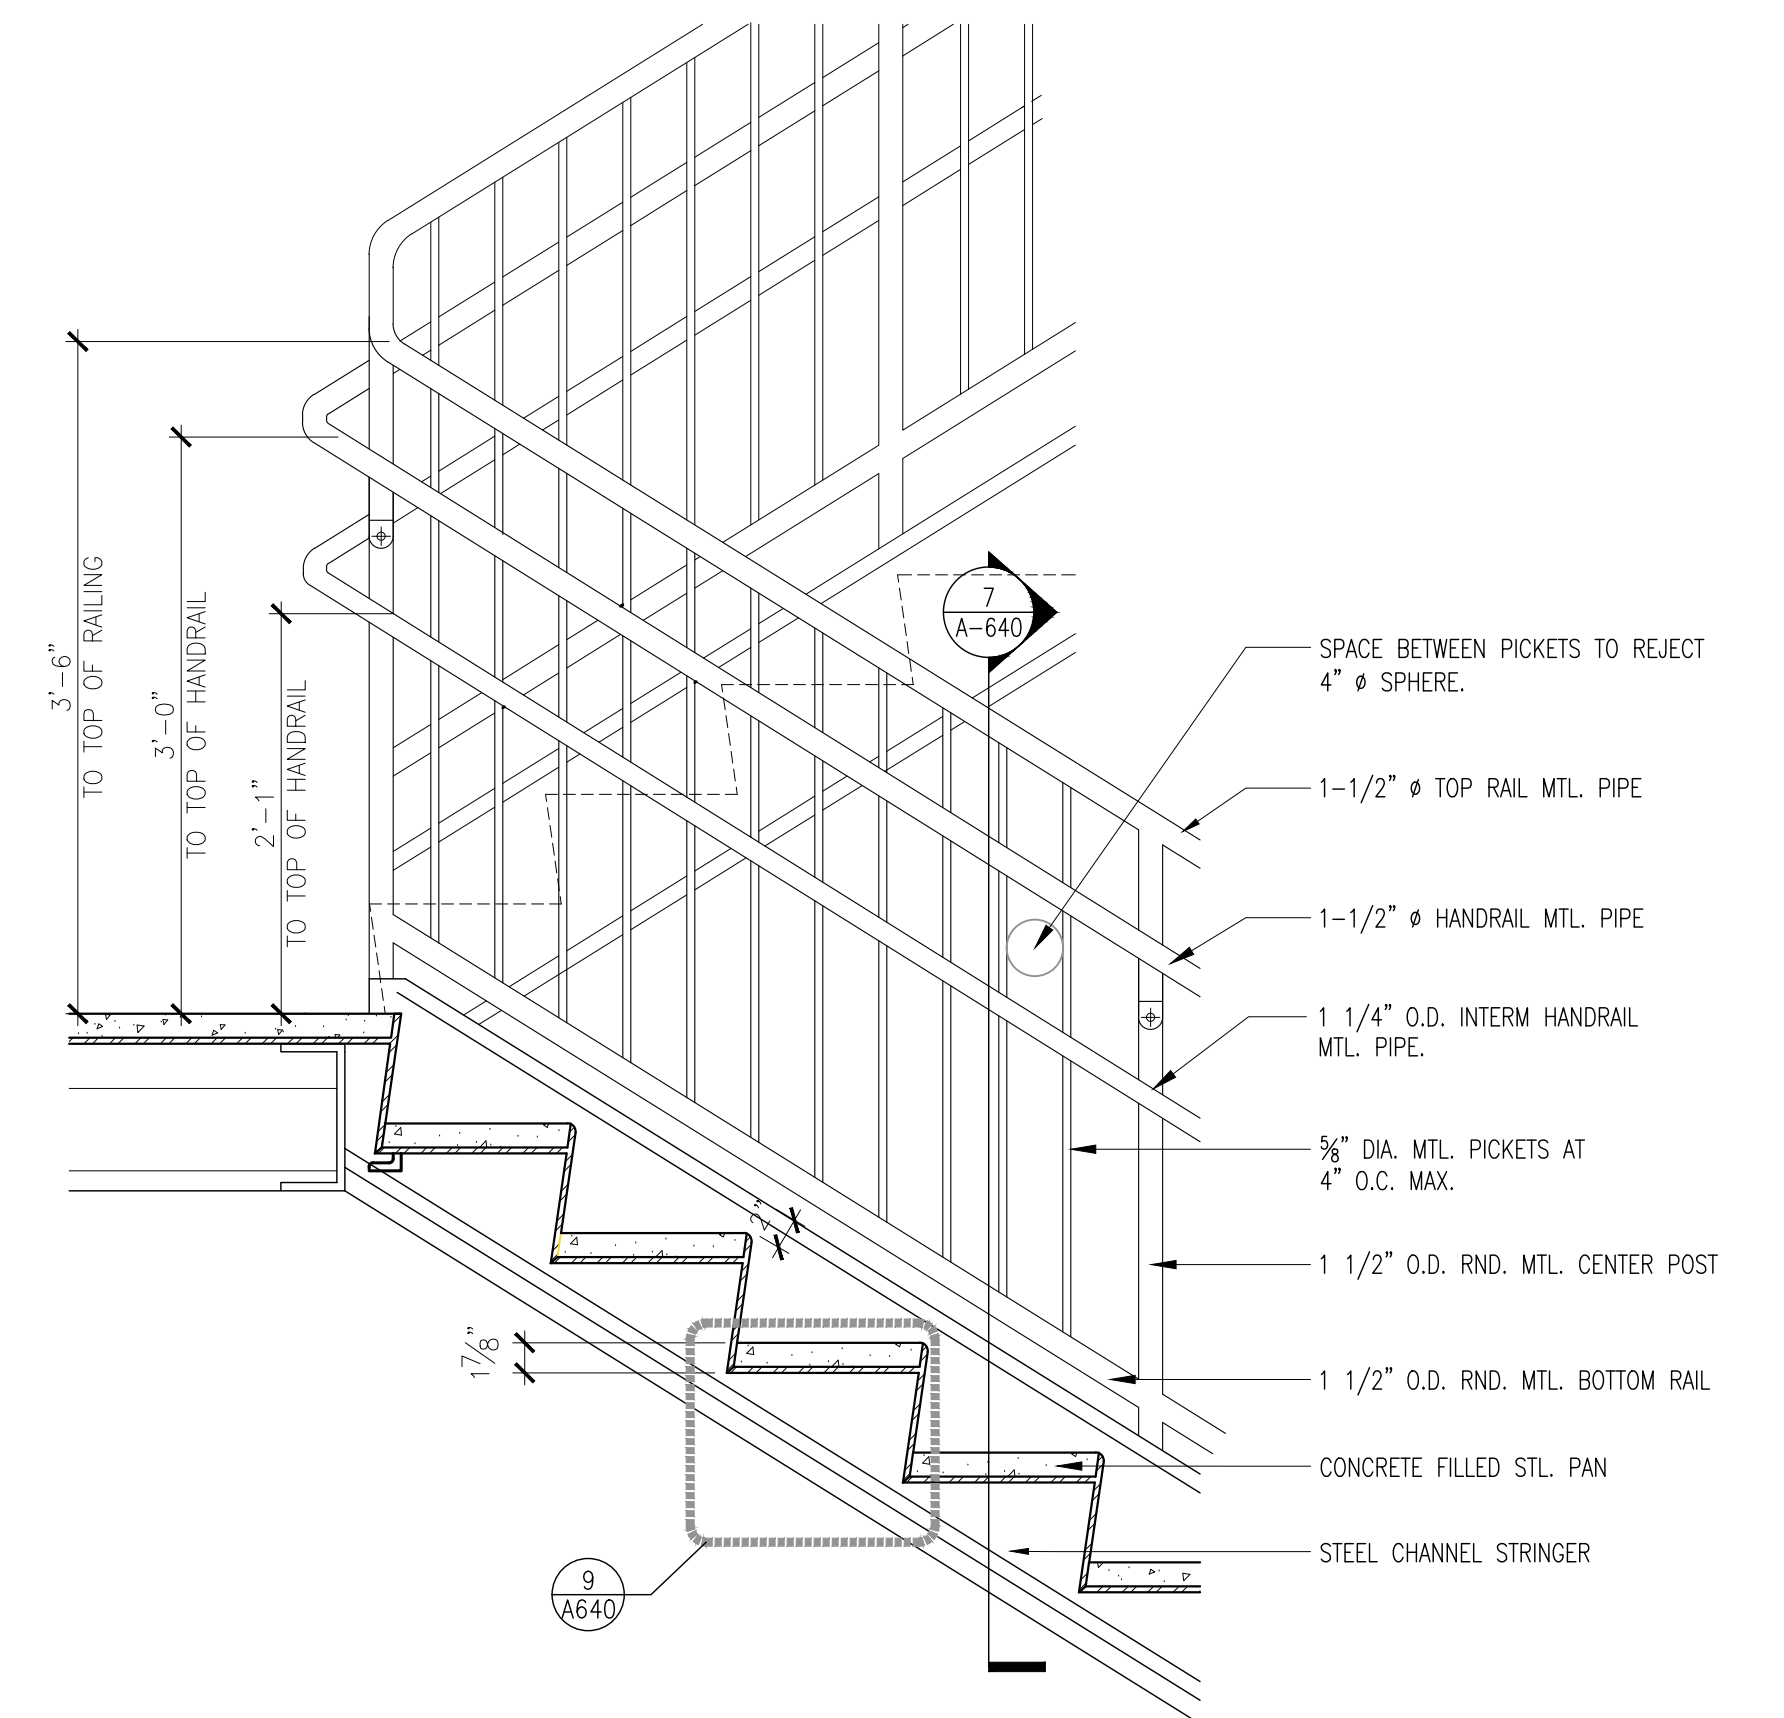


2 RAILING DETAIL @ METAL STAIR
A-640 SCALE: 1" = 1'-0"

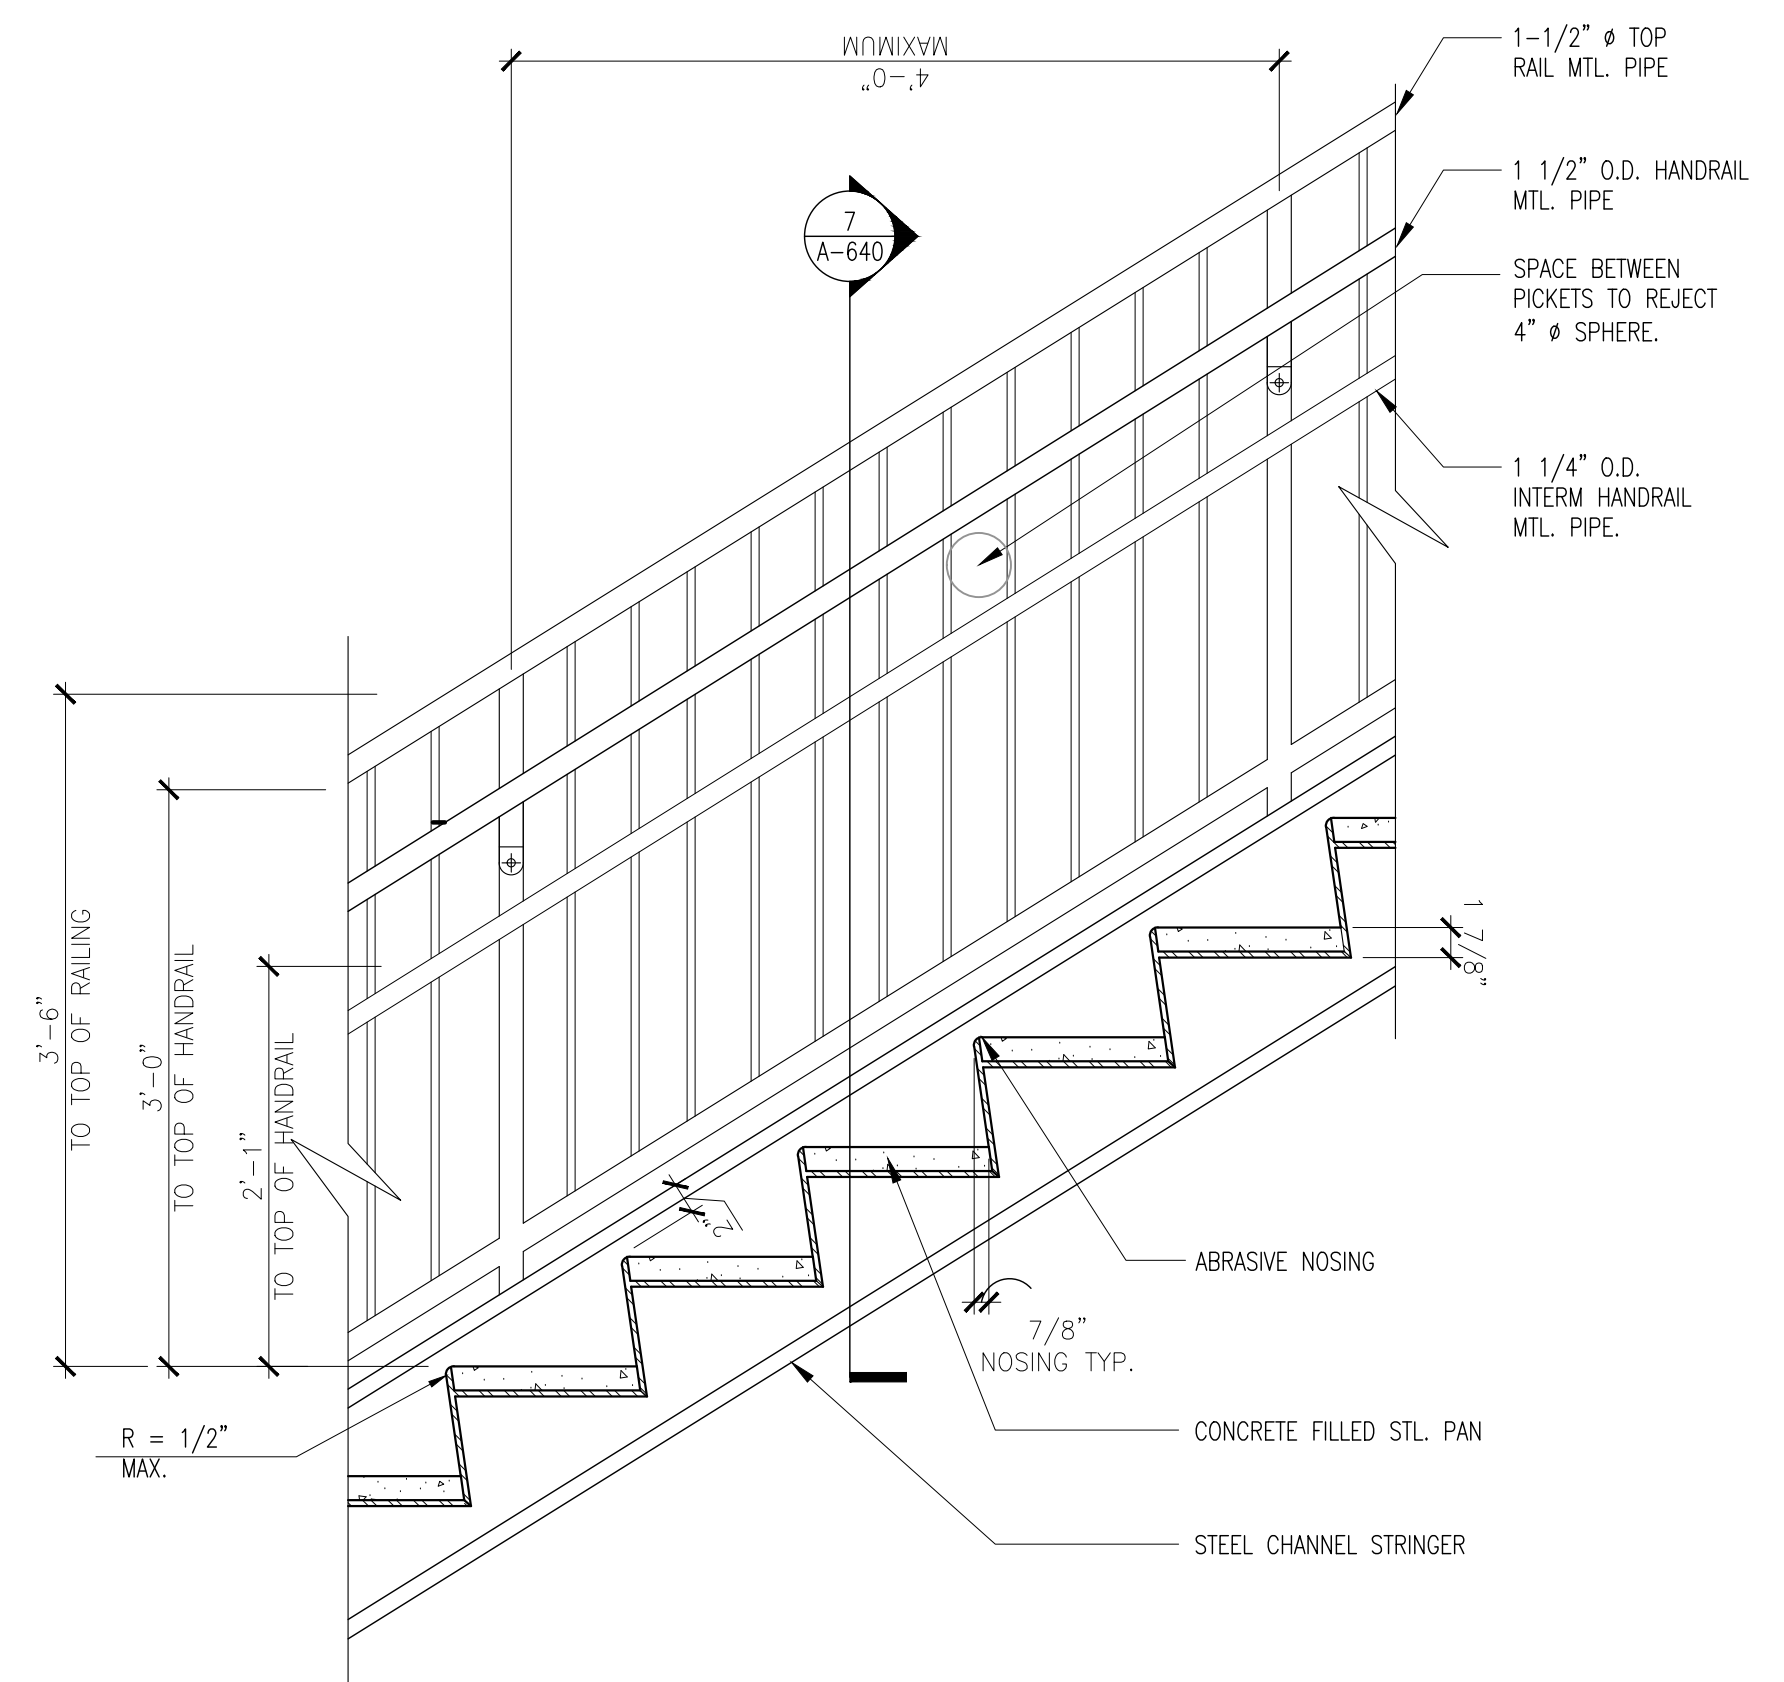

1 RAILING DETAIL @ METAL STAIR
A-640 SCALE: 1" = 1'-0"


CHECKED BY: LR	DRAWN BY: CV
-------------------	-----------------

CONSULTANT INFO:

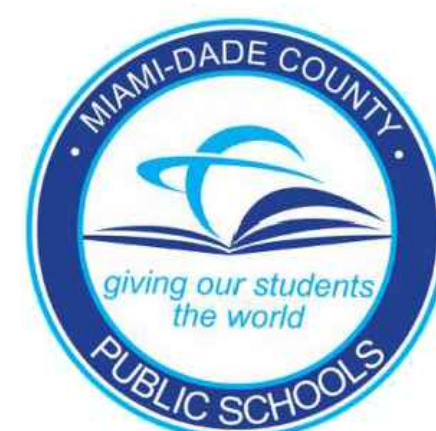

NEW ELEMENTARY SCHOOL (K-5)
VENETIAN PARC WEST
SOUTHWEST 157th AVENUE and 174th STREET
MIAMI, FL. 33187
MDCPS PROJECT No. 01892600

KEY PLAN

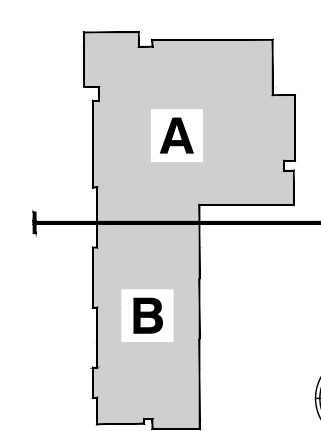

CONSULTANT INFO:

RODRIGUEZ ARCHITECTS
INCORPORATED
2121 PONCE DE LEON BLVD. STE 1010
CORAL GABLES, FL. 33134
TEL: (305) 448-3373
FAX: (305) 448-3374
A A C - 0 0 1 9 3 3

RODRIGUEZ ARCHITECTS
INCORPORATED
2121 PONCE DE LEON BLVD. STE 1010
CORAL GABLES, FL. 33134
TEL: (305) 448-3373
FAX: (305) 448-3374
A A C - 0 0 1 9 3 3



REVISIONS:






DRAWING TITLE:

RAILING & STAIR DETAILS

SCALE: AS NOTED

ISSUE DATE: 12/16/14 PROJECT NO. 1906

SHEET: A-640

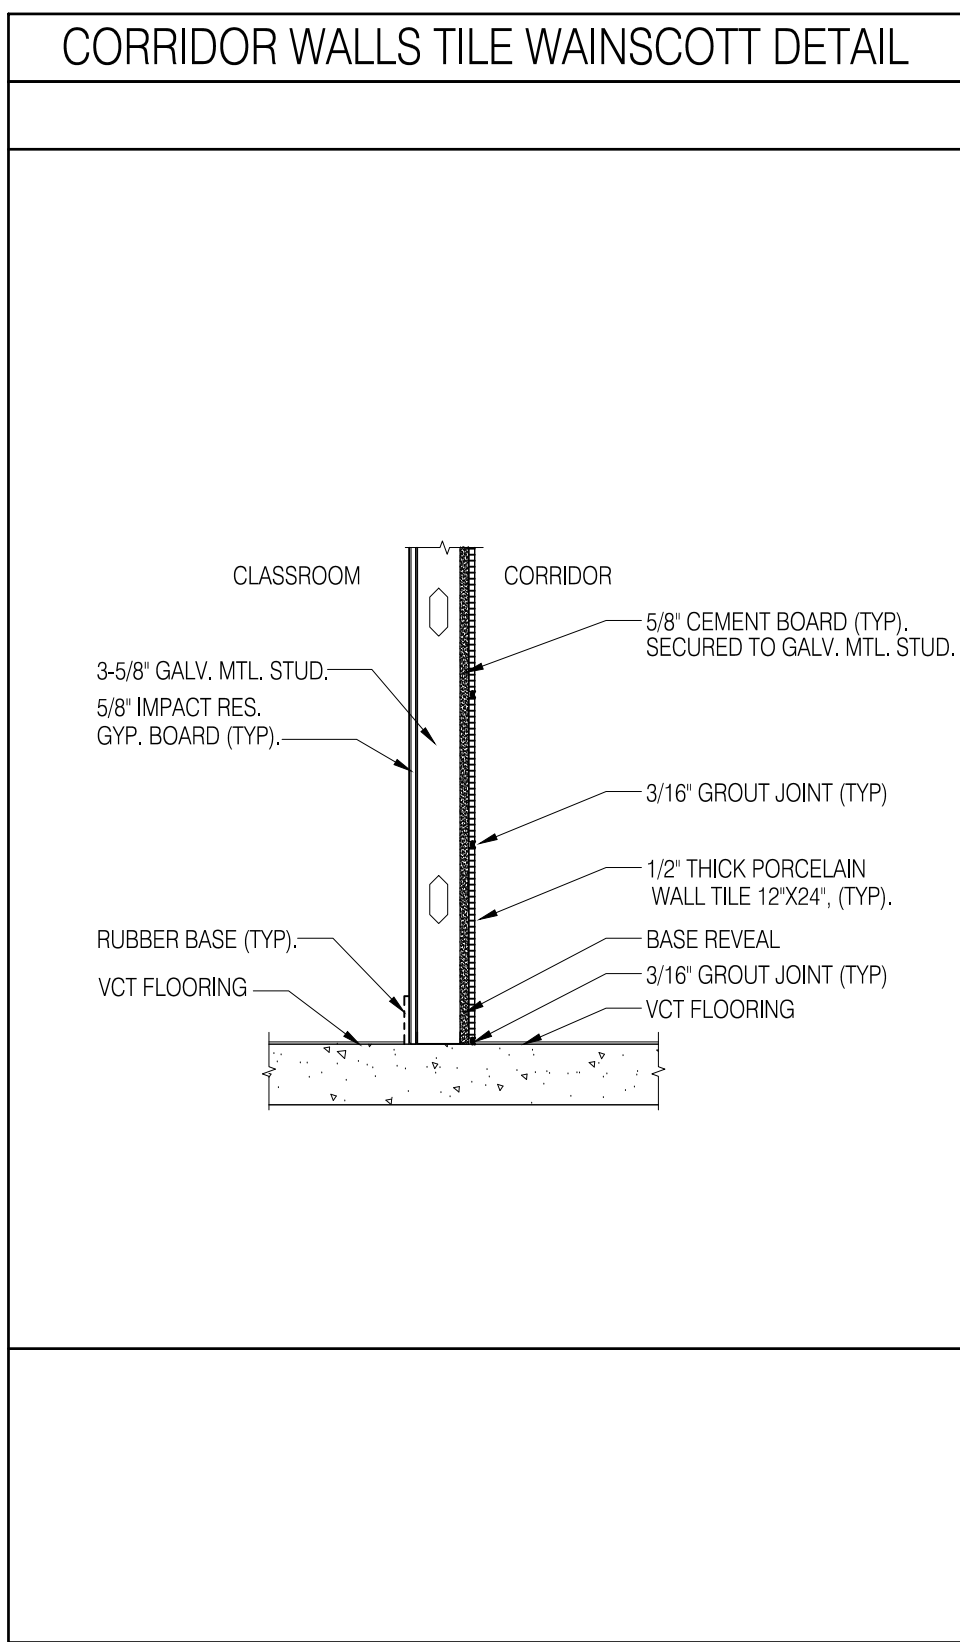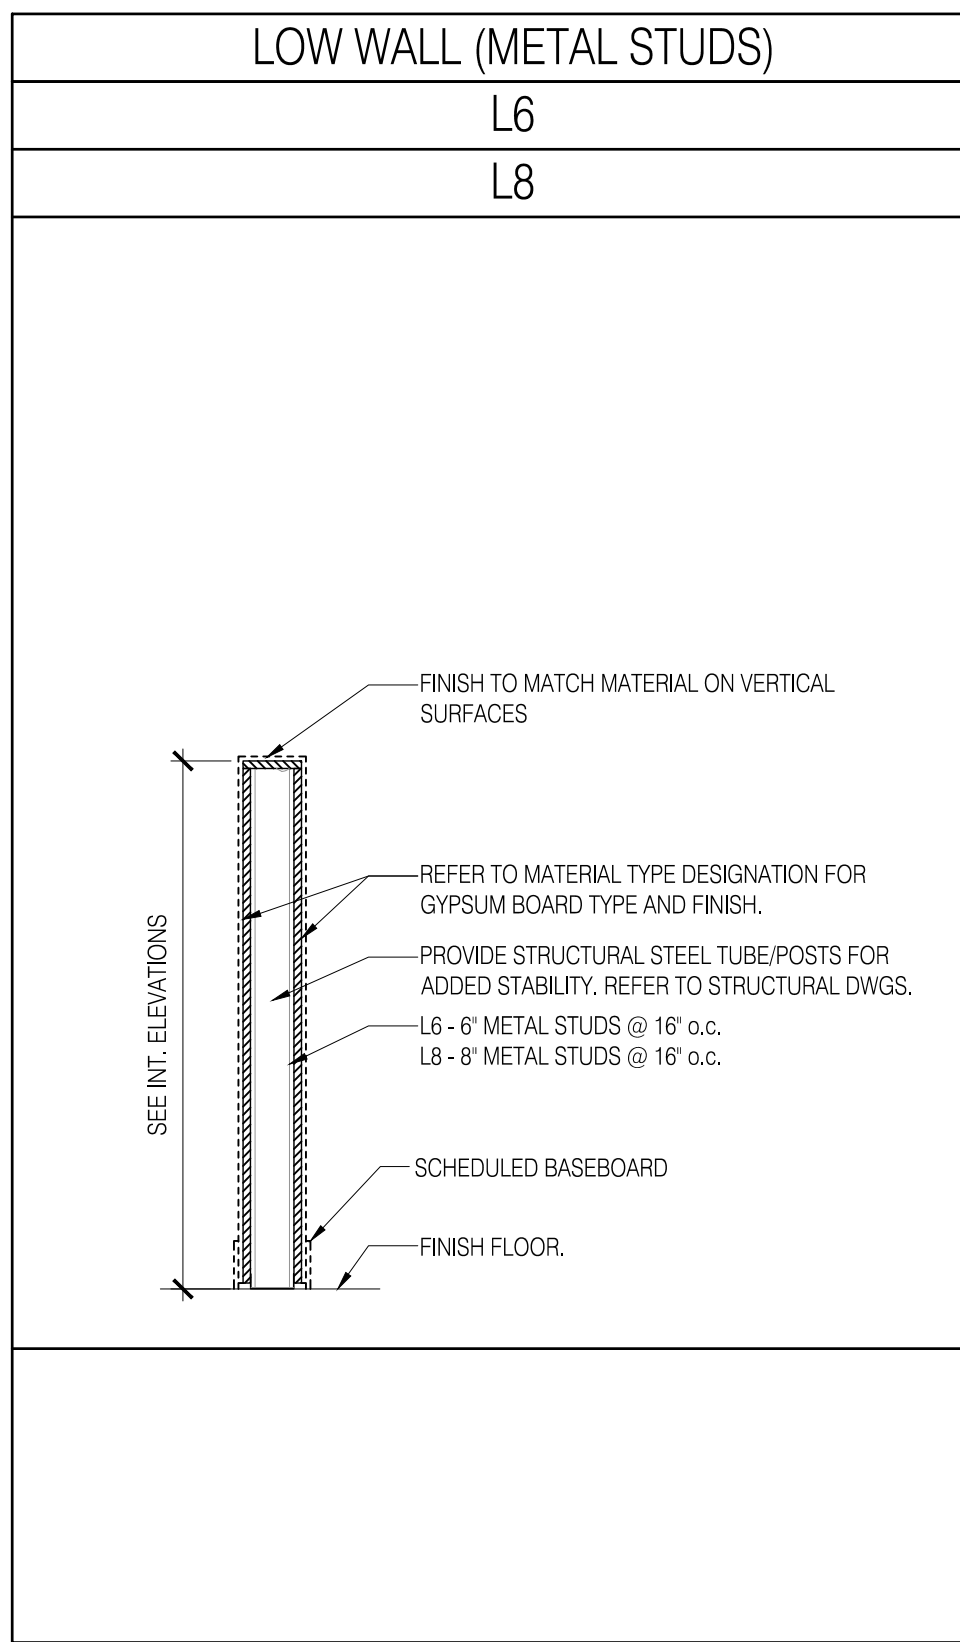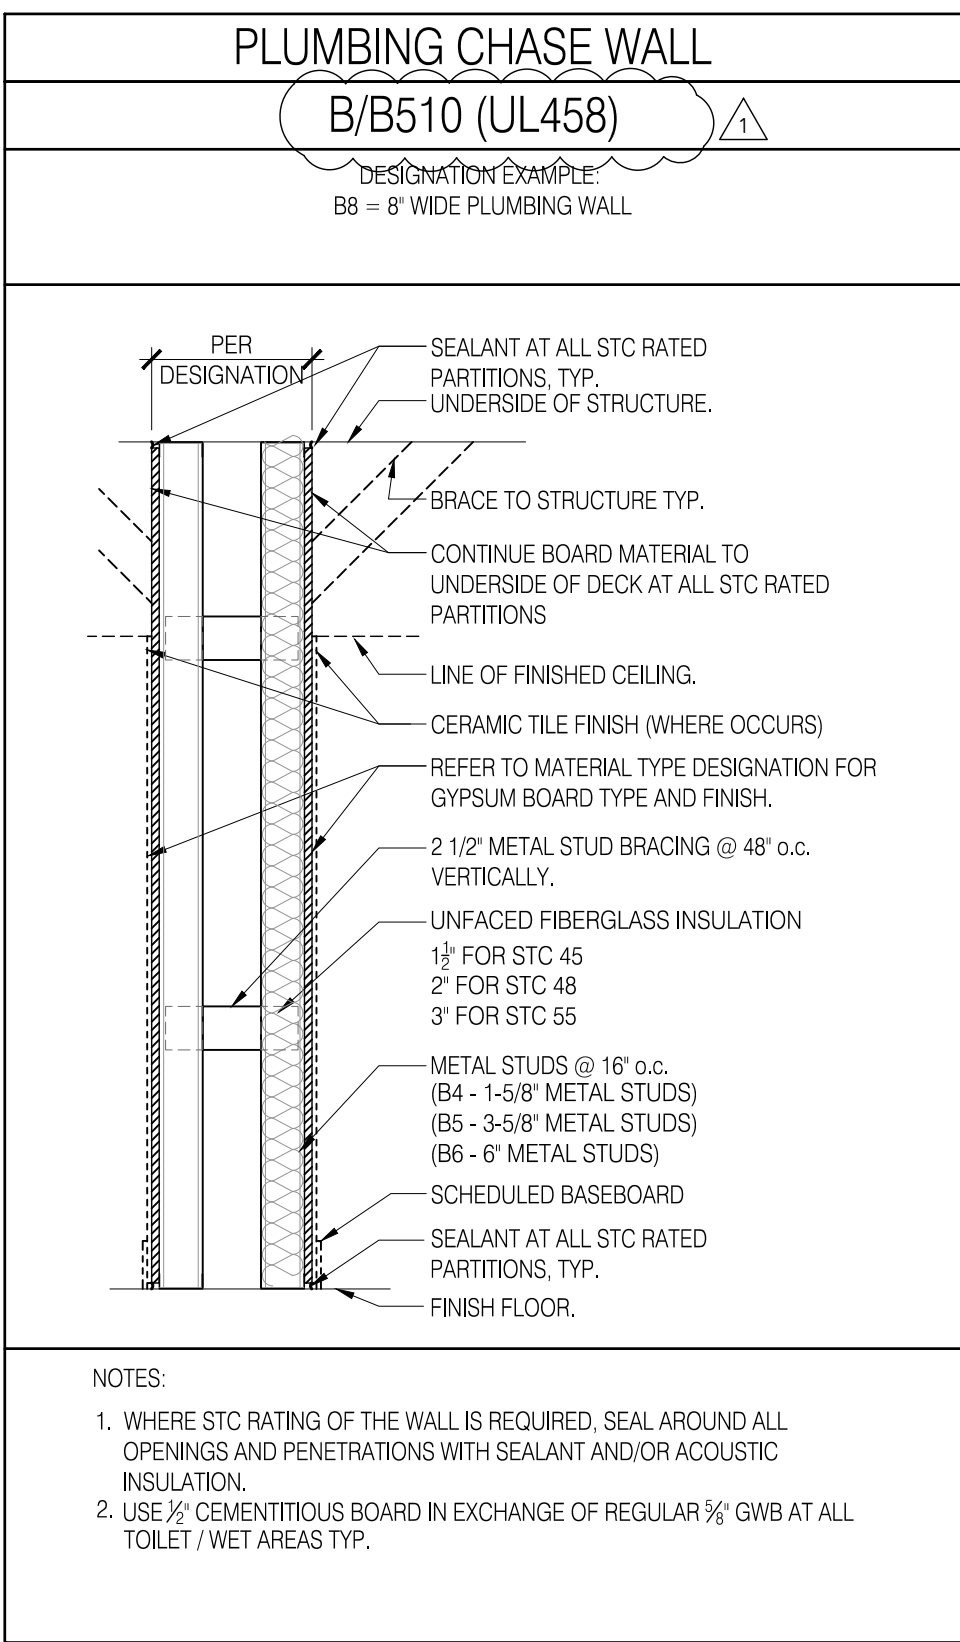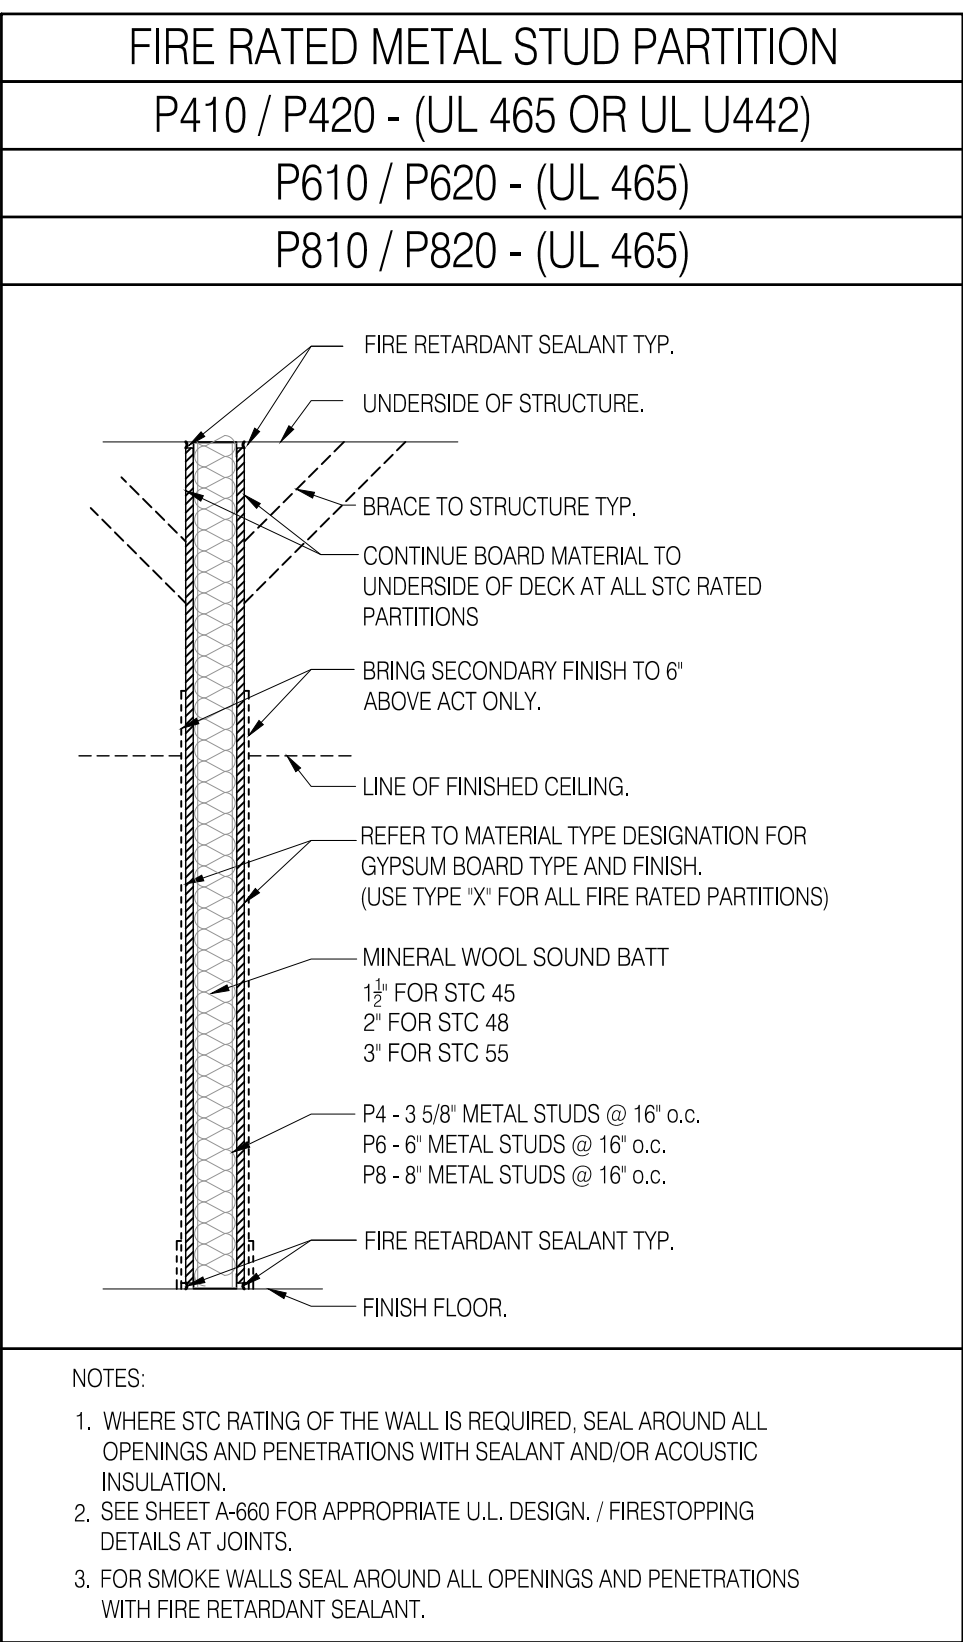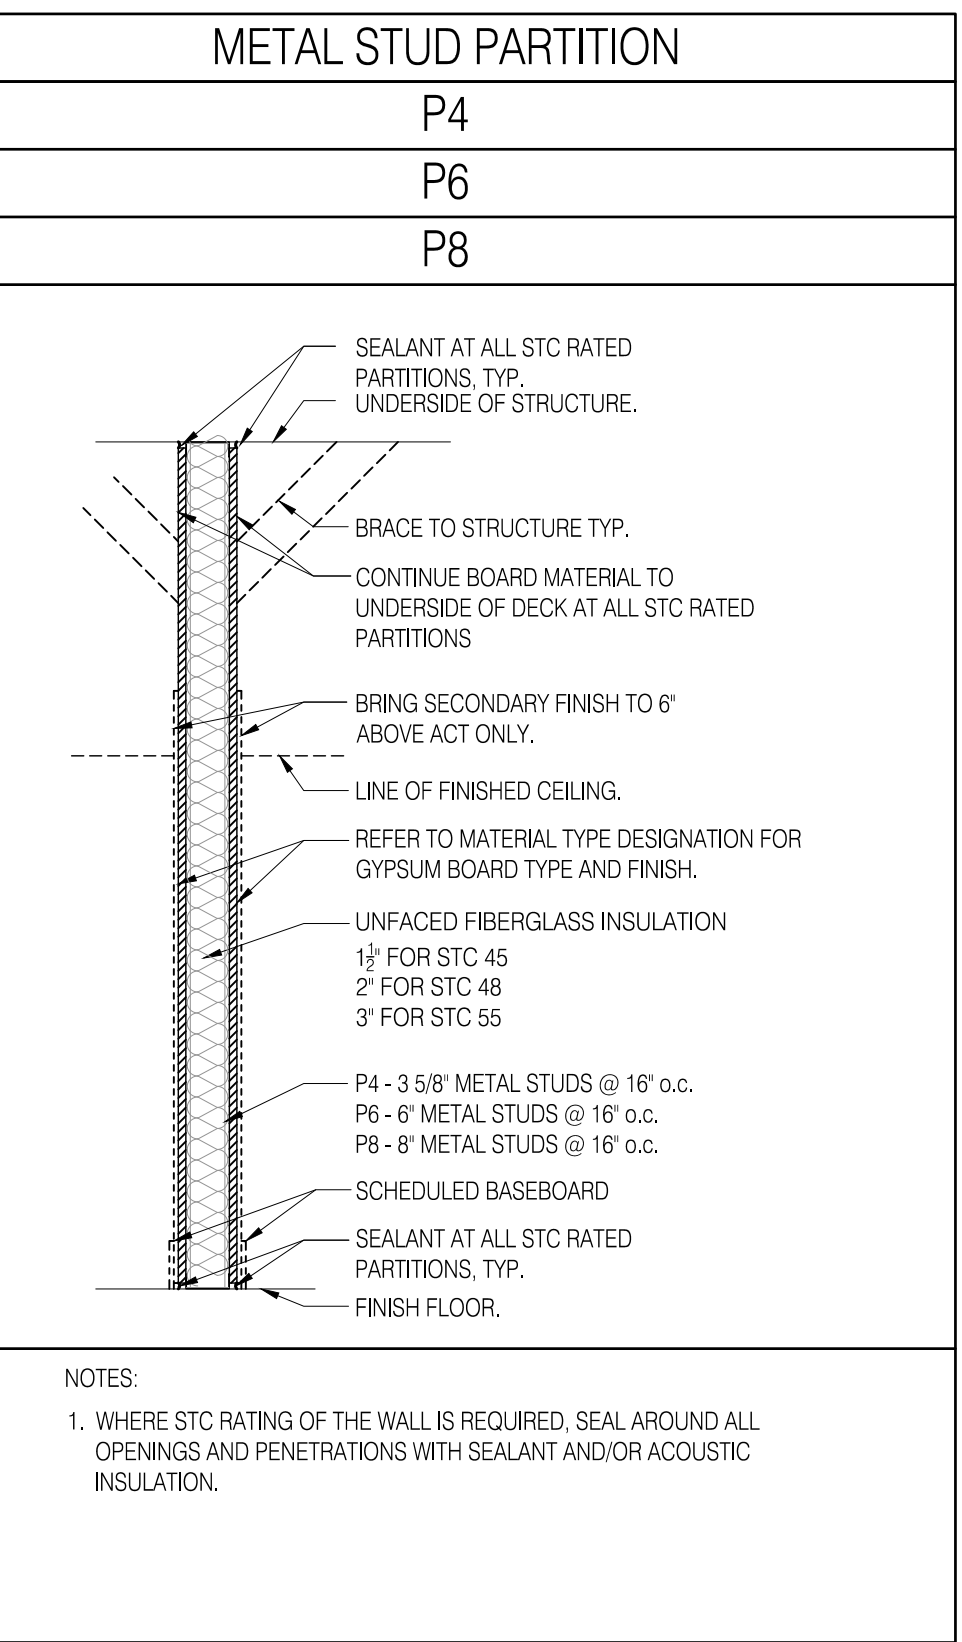

TYPE	DEFINITION
01	5/8\"/>

L4
00/00

TYPE	DEFINITION
01	5/8\"/>


B6
00/00

TYPE	DEFINITION
01	5/8\"/>

P410
00/00


TYPE	DEFINITION
01	5/8\"/>

P4
00/00

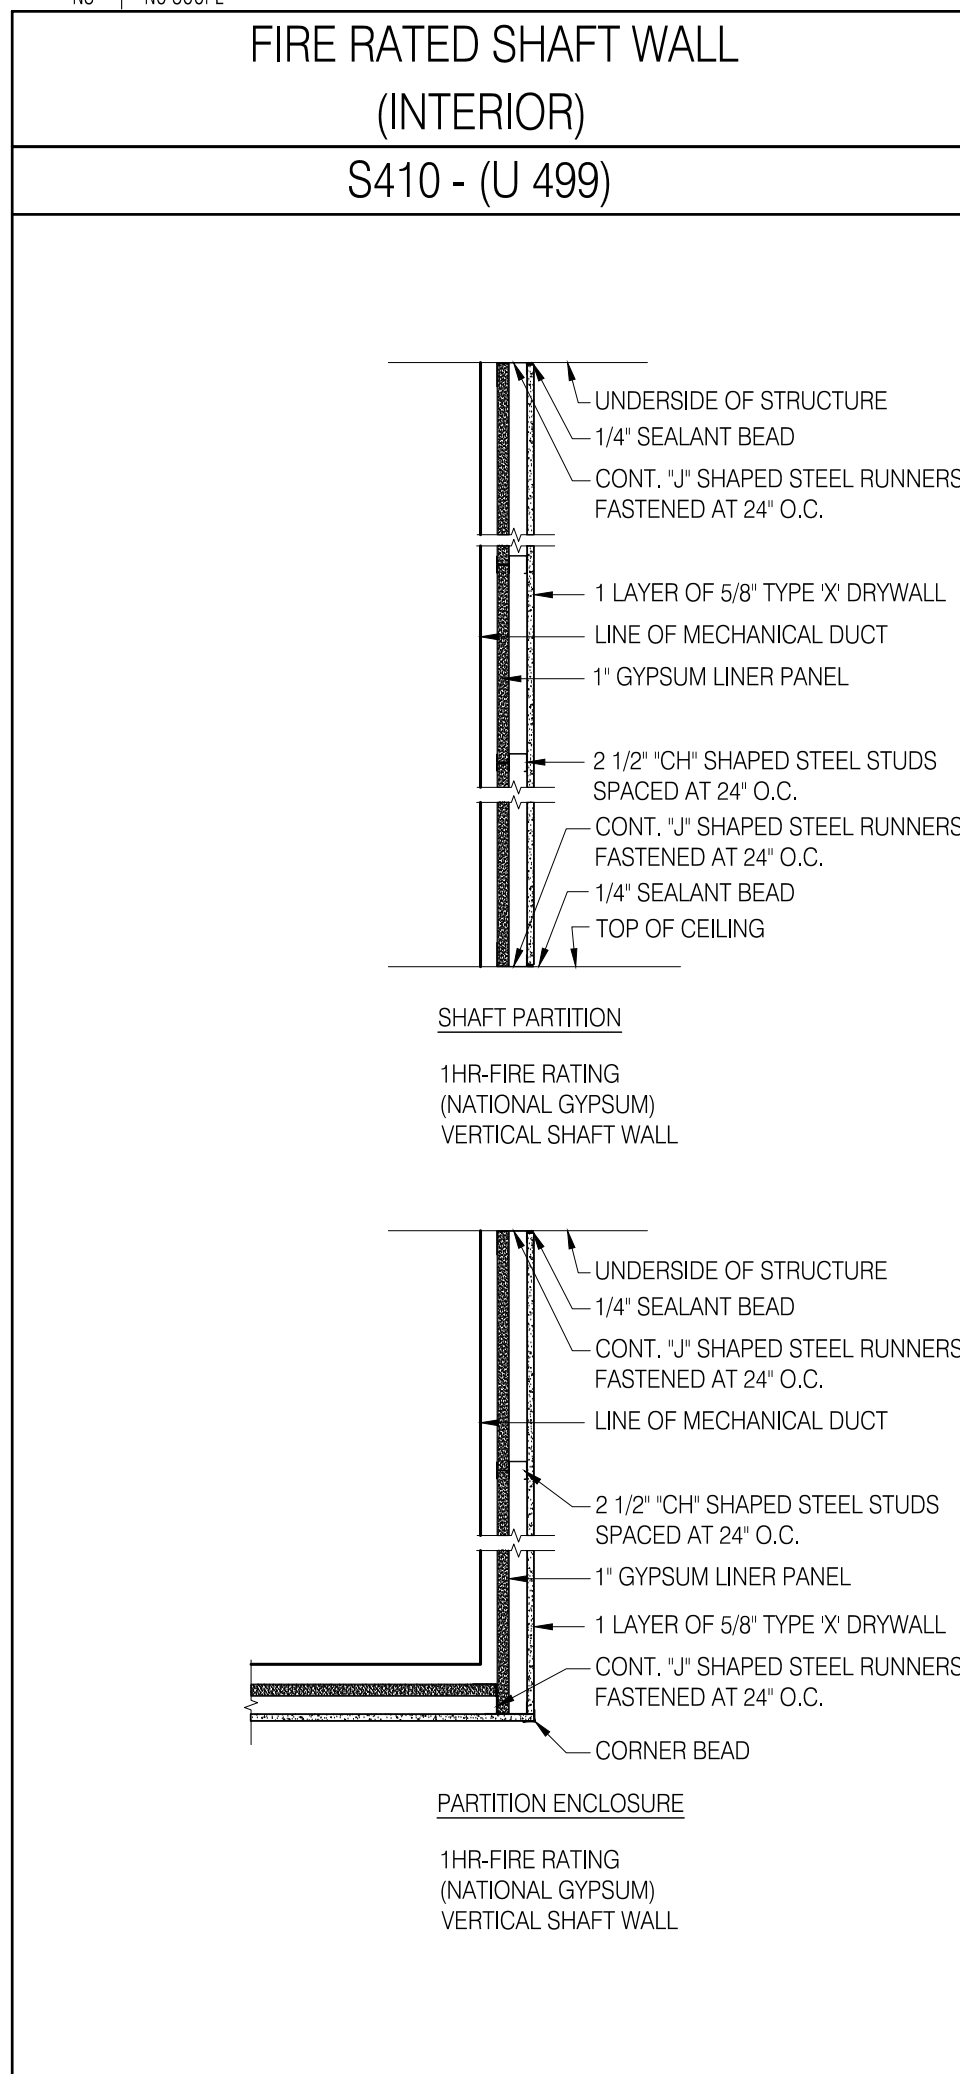


TYPE	DEFINITION
01	5/8\"/>

S410
00/00

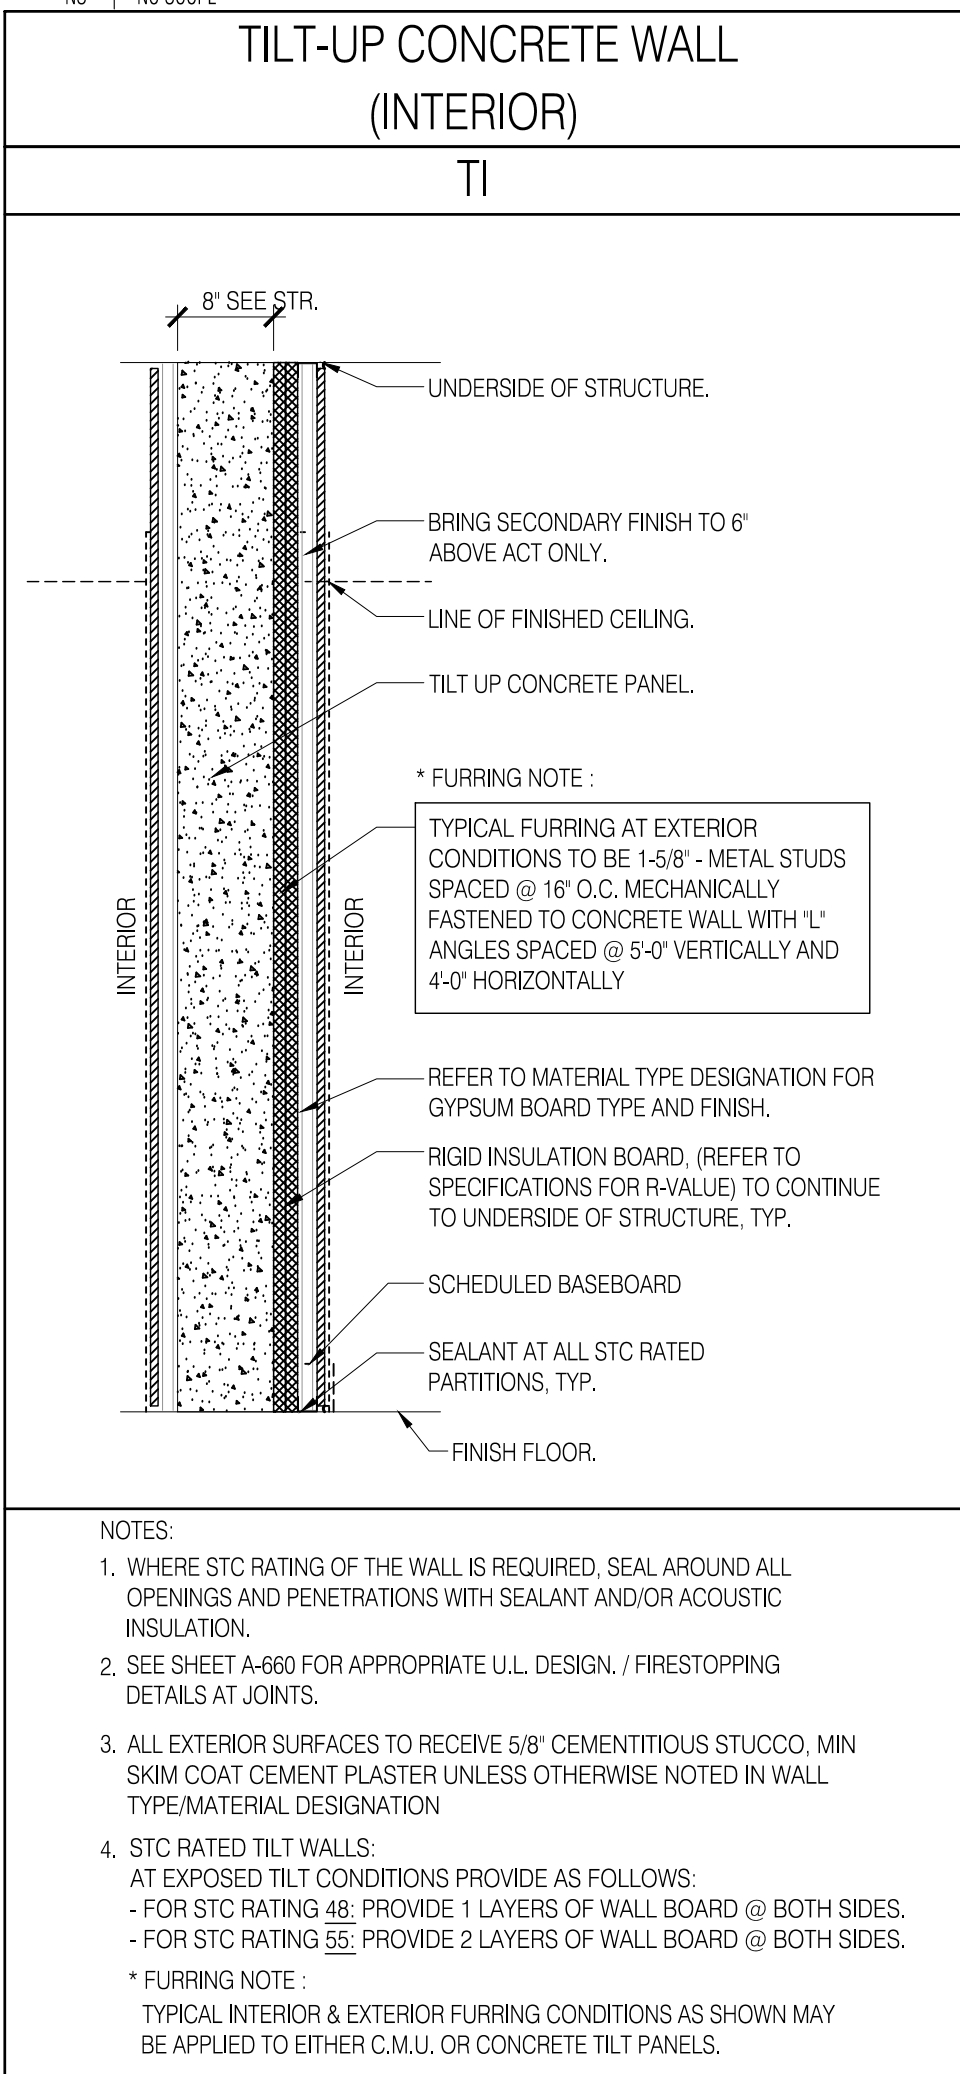


TYPE	DEFINITION
01	5/8\"/>

T1
00/00

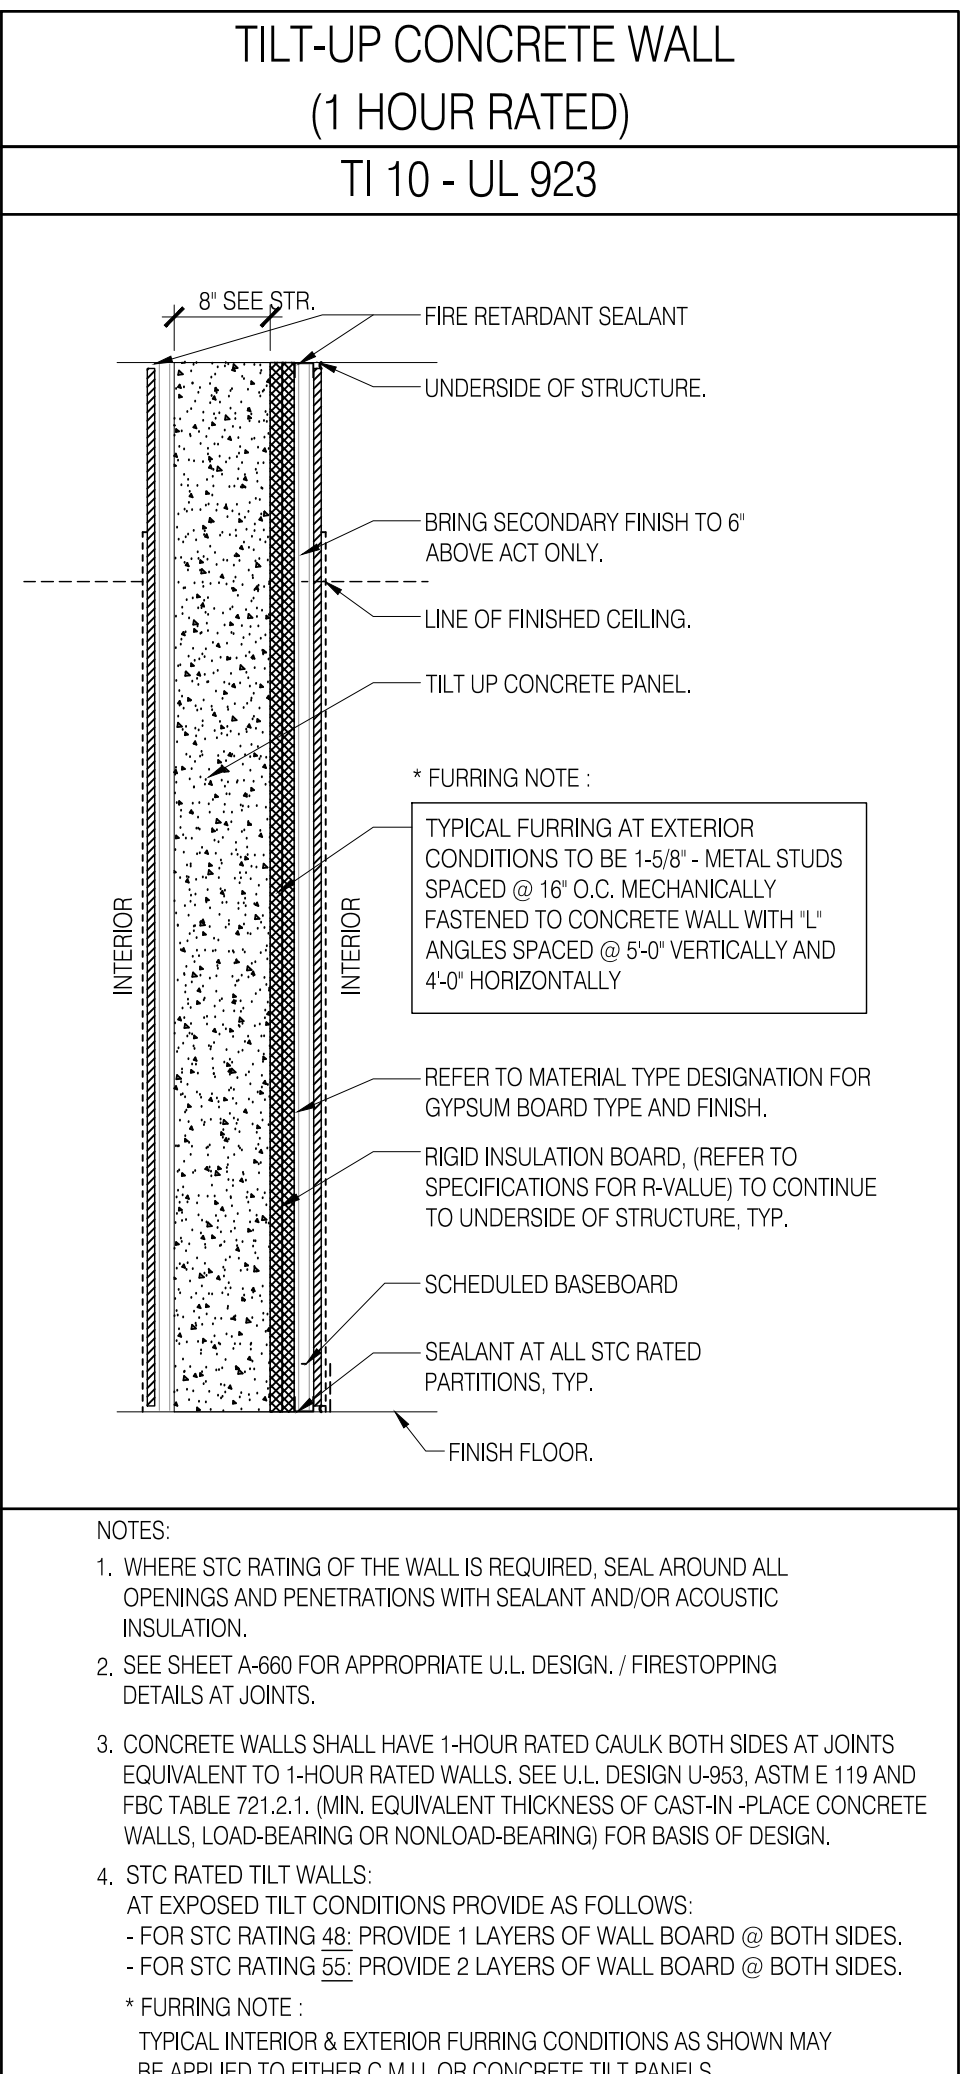

TYPE	DEFINITION
01	5/8\"/>

T1 10
00/00

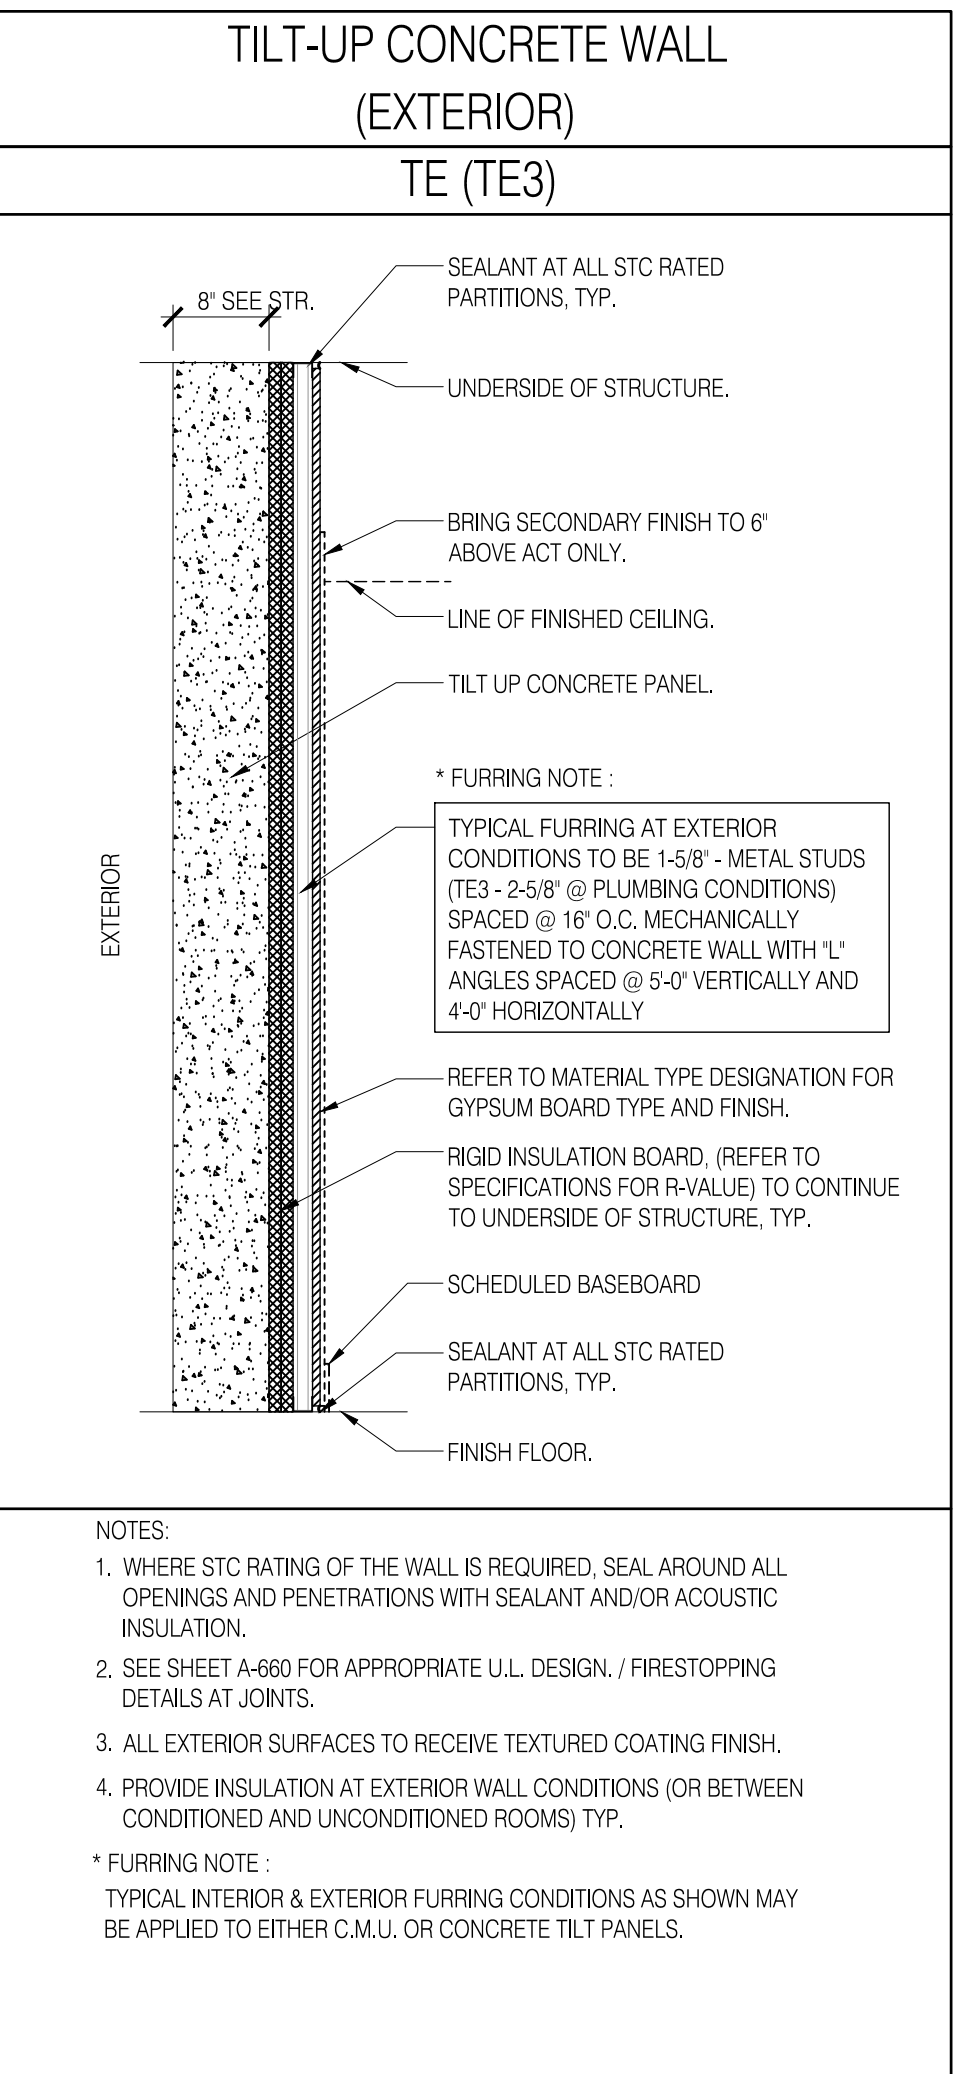

TYPE	DEFINITION
01	5/8\"/>

TE
00/00

WALL TYPE NOTES & LEGEND

1. PROVIDE IMPACT RESISTANT WALL BOARD FOR THE FIRST 4'-0\"/>

NOTE:
ALL WALL PARTITIONS SERVING OFFICES, RESTROOMS, KITCHEN, MULTIPURPOSE ROOM, CLASSROOMS, LABS AND REGULARLY OCCUPIED SPACES SHALL MEET A MINIMUM ASSEMBLY ACOUSTIC SEPARATION OF STC-45.
INSTALL IRON INSTALLATION BOARD TO ACHIEVE AN R13 VALUE UNLESS OTHERWISE NOTED ALONG INTERIOR PERIMETER OF BUILDING.

LEGEND

OSO - ONE SIDE ONLY
BS - BOTH SIDES
SIDE A THE SIDE THE TAG IS ON
SIDE B THE OTHER SIDE
CP - CEMENT PLASTER
GP - GYPSUM PLASTER

WALL PRIORITY LEGEND

CONSTRUCTION	PRIORITY
TWO HOUR FIRE AND SMOKE WALL	1 HIGHEST
TWO HOUR FIRE WALL	2
TWO HOUR SHAFT WALL	2
ONE HOUR FIRE AND SMOKE WALL	3
ONE HOUR FIRE WALL	4
NON-RATED WALL	5

WALL TAG KEY

EXAMPLE:
P4 45 02 05
3\"/>


MATERIAL TYPE KEY

TYPE	DEFINITION
01	5/8\"/>

MASONRY / PRECAST PANEL TYPES

TYPE	DEFINITION
01	5/8\"/>

			CONSTRUCTION ASSEMBLY																				
			WALLS/PARTITIONS			COLUMNS												FLOORS		ROOF			
PENETRATING ITEM	CONCRETE (3 HOUR), U 916	CONCRETE (2 HOUR), U 905	CMU (2 HOUR) 905	CMU (1-HOUR), U 905	MIL STUD (2 HOUR) U 412	MIL STUD (1 HOUR), U 405 OR U 442	SHAFT WALL (2 HOUR), U 438 OR U 497 OR (1 HOUR), U 499	PLUMBING CHASE WALL, U 438	COLUMN (2-3 HOURS) U X226	COLUMN (4 HOURS) U X533	CONCRETE (2 HOUR)	CONCRETE (3 HOUR) J708, J709, 716	COMPOSITE (2 HOURS) D-239	STRUCT. CONCRETE	CONCRETE/LIGHTWEIGHT (1 HOUR)	COMPOSITE (1 HOUR)	METAL DECK (1 HOUR)						
COPPER < 4" METAL PIPES < 30"	C-AJ-1064 Tremco C-AJ-1302 Tremco CA-J-1226 HILTI	C-AJ-1007 3M CA-J-1044 3M C-AJ-1198 STI CA-J-1226 HILTI C-AJ-1235 Grace CA-AJ-1404 Grace C-AJ-1302 Tremco C-AJ-1064 Tremco	C-AJ-1007 3M CA-J-1044 3M C-AJ-1198 STI CA-J-1226 HILTI CA-J-1235 Grace C-AJ-1404 Grace C-AJ-1302 Tremco C-AJ-1064 Tremco	CA-J-1013 3M C-AJ-1007 3M CA-J-1044 3M CA-J-1198 STI CA-J-1235 Grace C-AJ-1404 Grace C-AJ-1302 Tremco C-AJ-1064 Tremco	W-L-1001 3M W-L-1064 USG W-L-1049 STI W-L-1054 HILTI W-L-1152 Grace W-L-1158 Tremco W-L-5081 Tremco	W-L-1001 3M W-L-1064 USG W-L-1049 STI W-L-1054 HILTI W-L-1152 Grace W-L-1158 Tremco W-L-5081 Tremco	W-L-1001 3M W-L-1054 HILTI W-L-1152 Grace F-C-1050 Tremco F-C-5055 Tremco	W-L-1001 3M W-L-1054 HILTI W-L-1152 Grace F-E-1050 Tremco F-E-5055 Tremco	ENGINEERING JUDGMENT	ENGINEERING JUDGMENT	C-AJ-1007 3M CA-J-1044 3M C-AJ-1198 STI CA-J-1226 HILTI C-AJ-1235 Grace C-AJ-1404 Grace C-AJ-1302 Tremco C-AJ-1064 Tremco	C-AJ-1007 3M CA-J-1044 3M C-AJ-1198 STI CA-J-1226 HILTI CA-J-1226 Grace C-AJ-1404 Grace C-AJ-1302 Tremco C-AJ-1064 Tremco	C-AJ-1007 3M CA-J-1044 3M C-AJ-1198 STI F-A-1014 HILTI C-AJ-1235 Grace C-AJ-1235 Grace C-AJ-1404 Grace C-AJ-1302 Tremco C-AJ-1064 Tremco	C-AJ-1007 3M CA-J-1044 3M C-AJ-1198 STI CA-J-1226 HILTI C-AJ-1235 Grace C-AJ-1404 Grace C-AJ-1302 Tremco C-AJ-1064 Tremco	C-AJ-1007 3M CA-J-1044 3M C-AJ-1198 STI CA-J-1226 HILTI C-AJ-1235 Grace C-AJ-1404 Grace F-E-1011 Tremco F-E-5006 Tremco	F-A-1014 HILTI	F-A-1014 HILTI F-A-1016 HILTI F-A-1028 HILTI F-A-1029 HILTI						
MULTIPLE PIPES	CA-J-8041 HILTI CA-J-8056 HILTI CA-J-1140 HILTI	C-AJ-8001 3M C-BJ-1020 3M C-AJ-1048 STI CA-J-1140 HILTI CA-J-1172 HILTI CA-J-1174 HILTI C-AJ-1406 Grace C-AJ-1426 Grace C-AJ-8101 Grace C-AJ-8165 Tremco C-AJ-8057 Tremco C-AJ-1448 Tremco	C-AJ-8001 3M C-BJ-1020 3M C-AJ-1048 STI CA-J-1140 HILTI CA-J-1172 HILTI CA-J-1174 HILTI C-AJ-1406 Grace C-AJ-1426 Grace C-AJ-8101 Grace C-AJ-8165 Tremco C-AJ-8057 Tremco C-AJ-1448 Tremco	C-AJ-8001 3M C-BJ-1020 3M C-AJ-1048 STI CA-J-1140 HILTI CA-J-1172 HILTI CA-J-1174 HILTI C-AJ-1406 Grace C-AJ-1426 Grace C-AJ-8101 Grace C-AJ-8165 Tremco C-AJ-8057 Tremco C-AJ-1448 Tremco	W-L-1001 3M W-L-1057 HILTI W-L-1095 HILTI W-L-8013 HILTI W-L-1207 Grace W-L-8007 Grace W-L-1302 Tremco W-L-1020 Tremco	W-L-1001 3M W-L-1057 HILTI W-L-1095 HILTI W-L-8013 HILTI W-L-1207 Grace W-L-8007 Grace W-L-1302 Tremco W-L-1020 Tremco	W-L-1001 3M W-L-1057 HILTI W-L-1095 HILTI W-L-8013 HILTI W-L-1207 Grace W-L-8007 Grace W-L-1302 Tremco W-L-1020 Tremco	W-L-1001 3M W-L-1057 HILTI W-L-1095 HILTI W-L-8013 HILTI W-L-1207 Grace W-L-8007 Grace W-L-1302 Tremco W-L-1020 Tremco	ENGINEERING JUDGMENT	ENGINEERING JUDGMENT	C-AJ-8001 3M C-BJ-1020 3M C-AJ-1048 STI CA-J-1140 HILTI CA-J-1172 HILTI CA-J-1174 HILTI C-AJ-1406 Grace C-AJ-1426 Grace C-AJ-8101 Grace	C-AJ-8001 3M C-BJ-1020 3M C-AJ-1048 STI CA-J-1140 HILTI CA-J-1172 HILTI CA-J-1174 HILTI C-AJ-1406 Grace C-AJ-1426 Grace C-AJ-8101 Grace	C-AJ-8001 3M CA-J-1140 HILTI C-AJ-1406 Grace C-AJ-8101 Grace	CA-J-1140 HILTI CA-J-1172 HILTI CA-J-1174 HILTI	C-AJ-8096 HILTI C-AJ-1140 HILTI	CA-J-1140 HILTI	F-A-1022 HILTI F-A-1023 HILTI F-A-2103 HILTI						
INSULATED METAL PIPES < 12"	C-AJ-5090 HILTI C-AJ-5061 HILTI C-AJ-5185 HILTI	C-AJ-5096 HILTI C-AJ-5091 HILTI C-AJ-5090 HILTI C-AJ-5001 3M C-AJ-5060 3M C-AJ-5057 STI C-AJ-5116 Grace C-AJ-5175 Grace C-AJ-5208 Grace C-AJ-5111 Tremco C-AJ-5121 Tremco	C-AJ-5096 HILTI C-AJ-5091 HILTI C-AJ-5090 HILTI C-AJ-5001 3M C-AJ-5060 3M C-AJ-5057 STI C-AJ-5116 Grace C-AJ-5175 Grace C-AJ-5208 Grace C-AJ-5111 Tremco C-AJ-5121 Tremco	C-AJ-5096 HILTI C-AJ-5091 HILTI C-AJ-5090 HILTI C-AJ-5001 3M C-AJ-5060 3M C-AJ-5057 STI C-AJ-5116 Grace C-AJ-5175 Grace C-AJ-5208 Grace C-AJ-5111 Tremco C-AJ-5121 Tremco	W-L-1001 3M W-L-5029 HILTI W-L-5029 HILTI W-L-1064 USG W-L-5014 STI W-L-5171 Grace W-L-5172 Grace W-L-5081 Tremco W-L-5115 Tremco	W-L-1001 3M W-L-5029 HILTI W-L-5029 HILTI W-L-1064 USG W-L-5014 STI W-L-5171 Grace W-L-5172 Grace W-L-5081 Tremco W-L-5115 Tremco	W-L-5029 HILTI W-L-5171 Grace W-L-5172 Grace W-L-5081 Tremco W-L-5115 Tremco	W-L-5029 HILTI W-L-5171 Grace W-L-5172 Grace W-L-5081 Tremco W-L-5115 Tremco	ENGINEERING JUDGMENT	ENGINEERING JUDGMENT	C-AJ-5001 3M CA-J-5060 3M C-AJ-5057 STI C-AJ-5091 HILTI C-AJ-5090 HILTI CA-J-5096 Grace C-AJ-5116 Grace C-AJ-5175 Grace C-AJ-5208 Grace C-AJ-5111 Tremco C-AJ-5121 Tremco	C-AJ-5001 3M CA-J-5060 3M C-AJ-5057 STI C-AJ-5091 HILTI C-AJ-5090 HILTI CA-J-5096 Grace C-AJ-5116 Grace C-AJ-5175 Grace C-AJ-5208 Grace C-AJ-5111 Tremco C-AJ-5121 Tremco	C-AJ-5001 3M CA-J-5096 HILTI C-AJ-5116 Grace	C-AJ-5096 HILTI C-AJ-5091 HILTI C-AJ-5090 HILTI	C-AJ-5096 HILTI C-AJ-5091 HILTI C-AJ-5090 HILTI	F-A-5021 HILTI F-A-5019 HILTI F-A-5018 HILTI							
INSULATED CABLES/ TELEPHONE CABLES	C-AJ-3095 HILTI C-AJ-3181 HILTI C-AJ-3198 HILTI	C-AJ-3095 HILTI C-AJ-3030 3M C-AJ-3023 STI C-AJ-3153 Grace C-AJ-3198 Grace C-AJ-3141 Tremco C-AJ-3104 Tremco	C-AJ-3095 HILTI C-AJ-3030 3M C-AJ-3023 STI C-AJ-3153 Grace C-AJ-3198 Grace C-AJ-3141 Tremco C-AJ-3104 Tremco	C-AJ-3095 HILTI C-AJ-3030 3M C-AJ-3023 STI C-AJ-3153 Grace C-AJ-3198 Grace C-AJ-3141 Tremco C-AJ-3104 Tremco	W-L-3001 3M W-L-3030 3M W-L-3065 HILTI W-L-3076 STI W-L-3179 Grace W-L-3199 Grace W-L-3131 Tremco	W-L-3001 3M W-L-3030 3M W-L-3065 HILTI W-L-3076 STI W-L-3179 Grace W-L-3199 Grace W-L-3131 Tremco	W-L-3001 3M W-L-3030 3M W-L-3065 HILTI W-L-3076 STI W-L-3179 Grace W-L-3199 Grace	N/A	ENGINEERING JUDGMENT	ENGINEERING JUDGMENT	C-AJ-3095 HILTI C-AJ-3030 3M C-AJ-3023 STI C-AJ-3153 Grace C-AJ-3199 Grace	C-AJ-3095 HILTI C-AJ-3030 3M C-AJ-3023 STI C-AJ-3153 Grace C-AJ-3199 Grace	C-AJ-3095 HILTI C-AJ-3030 3M C-AJ-3023 STI C-AJ-3153 Grace C-AJ-3199 Grace	C-AJ-3095 HILTI	C-AJ-3095 HILTI	C-AJ-3095 HILTI	F-A-3012 HILTI F-A-3007 HILTI						
CABLE TRAYS/CONDUITS	C-AJ-4035 HILTI C-AJ-4017 HILTI	C-AJ-4034 HILTI C-AJ-4035 HILTI C-AJ-4017 HILTI C-AJ-4003 3M C-BJ-4021 3M C-AJ-4029 STI C-AJ-4030 STI C-AJ-4053 Grace C-BJ-4024 Grace C-AJ-4075 Tremco	C-AJ-4034 HILTI C-AJ-4035 HILTI C-AJ-4017 HILTI C-AJ-4003 3M C-BJ-4021 3M C-AJ-4029 STI C-AJ-4030 STI C-AJ-4053 Grace C-BJ-4024 Grace C-AJ-4075 Tremco	C-AJ-4034 HILTI C-AJ-4035 HILTI C-AJ-4017 HILTI C-AJ-4003 3M C-BJ-4021 3M C-AJ-4029 STI C-AJ-4030 STI C-AJ-4053 Grace C-BJ-4024 Grace	W-L-4004 3M W-L-4011 HILTI W-L-4019 HILTI W-L-4003 3M W-L-4009 Grace W-L-4025 Grace W-L-4030 Grace W-L-4012 Tremco	W-L-4004 3M W-L-4011 HILTI W-L-4019 HILTI W-L-4003 3M W-L-4009 Grace W-L-4025 Grace W-L-4030 Grace W-L-4012 Tremco	W-L-4004 3M W-L-4011 HILTI W-L-4019 HILTI W-L-4003 3M W-L-4009 Grace W-L-4025 Grace W-L-4030 Grace	N/A	ENGINEERING JUDGMENT	ENGINEERING JUDGMENT	C-AJ-4003 3M C-BJ-4021 3M C-AJ-4029 STI C-AJ-4030 STI C-AJ-4034 HILTI C-AJ-4035 HILTI C-AJ-4017 HILTI C-AJ-4053 Grace C-BJ-4024 Grace	C-AJ-4003 3M C-BJ-4021 3M C-AJ-4029 STI C-AJ-4030 STI C-AJ-4034 HILTI C-AJ-4035 HILTI C-AJ-4017 HILTI C-AJ-4053 Grace C-BJ-4024 Grace	C-AJ-4003 3M C-AJ-4029 STI C-AJ-4030 STI C-AJ-4034 HILTI C-AJ-4035 HILTI C-AJ-4017 HILTI C-AJ-4053 Grace C-BJ-4024 Grace	C-AJ-4034 HILTI C-AJ-4035 HILTI C-AJ-4017 HILTI	C-AJ-4034 HILTI C-AJ-4035 HILTI C-AJ-4017 HILTI	C-AJ-4034 HILTI C-AJ-4035 HILTI C-AJ-4017 HILTI	F-A-4003 HILTI						
CONSTRUCTION JOINTS FLOOR/FLOOR	N/A	N/A	N/A	N/A	N/A	N/A	N/A	N/A	ENGINEERING JUDGMENT	ENGINEERING JUDGMENT	FF-D-1013 HILTI FF-S-200A C&S FF-D-1024 Grace FF-D-1027 Grace FF-D-1057 Tremco FF-D-0042 Tremco	FF-D-1011 HILTI FF-D-1004 3M FF-D-1024 Grace FF-D-1027 Grace FF-S-0023 Tremco FF-D-1057 Tremco FF-D-0042 Tremco	FF-D-1013 HILTI FF-S-200A C&S FF-D-1024 Grace FF-D-1027 Grace	FF-D-1013 HILTI	FF-D-1013 HILTI	FF-D-1013 HILTI	N/A						
CONSTRUCTION JOINTS FLOOR/WALL	FW-D-1011 HILTI FW-D-1021 HILTI	FW-D-1013 HILTI FW-D-1001 STI FW-D-1003 3M FW-D-1020 Grace FW-D-1024 Grace FW-D-0033 Tremco FW-D-1057 Tremco	FW-D-1013 HILTI FW-D-1001 STI FW-D-1003 3M FW-D-1020 Grace FW-D-1024 Grace	FW-D-1013 HILTI FW-D-1001 STI FW-D-1003 3M FW-D-1020 Grace FW-D-1024 Grace	N/A	N/A	N/A	N/A	ENGINEERING JUDGMENT	ENGINEERING JUDGMENT	FW-D-1013 HILTI FW-D-1003 3M FW-D-1001 STI FW-D-1020 Grace FW-D-1024 Grace	FW-D-1013 HILTI FW-D-1003 3M FW-D-1001 STI FW-D-1020 Grace FW-D-1024 Grace	FF-D-1013 HILTI	FF-D-1013 HILTI	N/A	N/A							
CONSTRUCTION JOINTS HEAD/WALL	HW-D-00261 HILTI HW-D-1008 HILTI HW-D-1058 HILTI HW-D-1002 HILTI	HW-D-0097 HILTI HW-D-1009 HILTI HW-D-1008 HILTI HW-D-0023 3M HW-D-0110 Grace HW-D-1020 Grace HW-D-1024 Grace HW-D-0017 Tremco HW-D-0092 Tremco	HW-D-0097 HILTI HW-D-1009 HILTI HW-D-1008 HILTI HW-D-0023 3M HW-D-0110 Grace HW-D-1020 Grace HW-D-1024 Grace HW-D-0017 Tremco HW-D-0092 Tremco	HW-D-0097 HILTI HW-D-1009 HILTI HW-D-1008 HILTI HW-D-0023 3M HW-D-0110 Grace HW-D-1020 Grace HW-D-1024 Grace	HW-D-0010 HILTI HW-D-0017 HILTI HW-D-1001 STI FW-D-1003 3M FW-D-1020 Grace FW-D-1024 Grace	HW-D-0010 HILTI HW-D-0082 HILTI HW-D-1008 HILTI HW-D-0023 3M HW-D-0107 Grace HW-D-0108 Grace HW-D-0147 Grace HW-D-0016 Tremco HW-D-0091 Tremco	HW-D-0010 HILTI HW-D-0082 HILTI HW-D-1008 HILTI HW-D-0023 3M HW-D-0107 Grace HW-D-0108 Grace HW-D-0147 Grace	HW-D-0010 HILTI HW-D-0082 HILTI HW-D-1008 HILTI HW-D-0023 3M HW-D-0107 Grace HW-D-0108 Grace HW-D-0147 Grace	ENGINEERING JUDGMENT	ENGINEERING JUDGMENT	N/A	N/A	HW-D-0042 HILTI WD-D-0077 HILTI WD-D-0098 HILTI WD-D-0013 3M WD-D-0002 USG WD-D-0107 Grace WD-D-0144 Grace	N/A	N/A	HW-D-0042 HILTI WD-D-0077 HILTI WD-D-0098 HILTI WD-D-0013 3M WD-D-0002 USG WD-D-0107 Grace WD-D-0144 Grace	N/A						
CONSTRUCTION JOINTS WALL/WALL	WW-D-1011 HILTI WW-D-1047 HILTI WWD-1032 WWD-1031	WW-D-1011 HILTI WW-D-1011 HILTI WW-D-1012 HILTI WW-D-1001 STI WW-D-1002 STI WW-D-1004 3M WW-D-1003 3M WW-D-0027 Grace WW-D-1029 Grace WW-D-1049 Tremco WW-D-1050 Tremco	WW-D-1011 HILTI WW-D-1011 HILTI WW-D-1012 HILTI WW-D-1001 STI WW-D-1002 STI WW-D-1004 3M WW-D-1003 3M WW-D-0027 Grace WW-D-1029 Grace WW-D-1049 Tremco WW-D-1050 Tremco	WW-D-1011 HILTI WW-D-1011 HILTI WW-D-1012 HILTI WW-D-1001 STI WW-D-1002 STI WW-D-1004 3M WW-D-1003 3M WW-D-0027 Grace WW-D-1029 Grace WW-D-1049 Tremco WW-D-1050 Tremco	WW-S-0004 3M WW-D-0017 HILTI WW-D-1011 HILTI WW-D-1012 HILTI WW-D-1001 STI WW-D-1002 STI WW-D-1004 3M WW-D-1003 3M WW-D-0027 Grace WW-D-1029 Grace	WW-S-0004 3M WW-D-0017 HILTI WW-D-1011 HILTI WW-D-1012 HILTI WW-D-1001 STI WW-D-1002 STI WW-D-1004 3M WW-D-1003 3M WW-D-0027 Grace WW-D-1029 Grace	WW-S-0004 3M WW-D-0017 HILTI WW-D-1011 HILTI WW-D-1012 HILTI WW-D-1001 STI WW-D-1002 STI WW-D-1004 3M WW-D-1003 3M WW-D-0027 Grace WW-D-1029 Grace	WW-S-0004 3M WW-D-0017 HILTI WW-D-1011 HILTI WW-D-1012 HILTI WW-D-1001 STI WW-D-1002 STI WW-D-1004 3M WW-D-1003 3M WW-D-0027 Grace WW-D-1029 Grace	ENGINEERING JUDGMENT	ENGINEERING JUDGMENT	N/A	N/A	N/A	N/A	N/A								
DUCTWORK	C-AJ-7046 HILTI C-AJ-7051 HILTI	W-J-0022 HILTI W-J-7021 HILTI C-AJ-7003 3M C-AJ-7016 3M C-AJ-7027 STI W-J-7023 Grace W-J-7045 Grace W-J-7069 Tremco C-AJ-7014 Tremco	W-J-0022 HILTI W-J-7021 HILTI C-AJ-7003 3M C-AJ-7016 3M C-AJ-7027 STI W-J-7023 Grace W-J-7045 Grace W-J-7069 Tremco	W-J-0022 HILTI W-J-7021 HILTI C-AJ-7003 3M C-AJ-7016 3M C-AJ-7027 STI W-J-7023 Grace W-J-7045 Grace	W-L-7040 HILTI W-L-7042 3M W-L-7008 3M W-L-7009 STI W-L-7046 Grace W-L-7081 Grace W-L-7039 Tremco	W-L-7003 HILTI W-L-7008 3M W-L-7009 STI W-L-7081 Grace	W-L-7040 HILTI W-L-7042 HILTI W-L-7008 3M W-L-7009 STI W-L-7046 Grace W-L-7081 Grace	W-L-7040 HILTI W-L-7042 HILTI W-L-7008 3M W-L-7009 STI W-L-7046 Grace W-L-7081 Grace	ENGINEERING JUDGMENT	ENGINEERING JUDGMENT	C-AJ-7003 3M C-AJ-7016 3M C-AJ-7027 STI C-AJ-7046 HILTI C-AJ-7051 HILTI C-AJ-7038 Grace C-AJ-7067 Grace C-AJ-7075 Grace	C-AJ-7003 3M C-AJ-7016 3M C-AJ-7027 STI C-AJ-7046 HILTI C-AJ-7051 HILTI C-AJ-7038 Grace C-AJ-7067 Grace C-AJ-7075 Grace	C-AJ-7003 3M C-AJ-7016 3M C-AJ-7027 STI C-AJ-7046 HILTI C-AJ-7051 HILTI C-AJ-7038 Grace C-AJ-7067 Grace C-AJ-7075 Grace	C-AJ-7046 HILTI C-AJ-7051 HILTI	C-AJ-7046 HILTI C-AJ-7051 HILTI	C-AJ-7046 HILTI C-AJ-7051 HILTI	N/A						

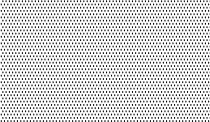	
CHECKED BY: L.R.	DRAWN BY: C.V.

UL/cUL SYSTEM NO. F-A-3007
SINGLE CABLE OR BUNDLED CABLE THROUGH CONCRETE FLOOR OR CONCRETE OVER METAL DECKING
F-RATING = 3-HR.
T-RATING = 0-HR.

1. CONCRETE FLOOR ASSEMBLY (3-HR. FIRE-RATING) :
A. LIGHTWEIGHT OR NORMAL WEIGHT CONCRETE FLOOR (MINIMUM 4-1/2" THICK).
B. STEEL FLOOR UNIT/FLOOR ASSEMBLY - NORMAL WEIGHT CONCRETE FLOOR (MINIMUM 4-1/2" THICK) OVER METAL DECKING.
2. SINGLE CABLE OR BUNDLED CABLE CONSISTING OF ANY OF THE FOLLOWING :
A. MAXIMUM 300 PAIR NO. 24 AWG TELEPHONE CABLE WITH PVC JACKET.
B. MAXIMUM 500 KCMIL POWER CABLE WITH PVC JACKET.
C. MAXIMUM 7/8" NO. 12 AWG POWER CABLE WITH PVC JACKET.
D. MAXIMUM (24 FIBER) 1/2" DIAMETER FIBER-OPTIC CABLE.
E. MAXIMUM 3/4" NO. 12 AWG METAL-CLAD CABLE.
3. HILTI CP 680 CAST-IN FIRESTOP DEVICE, CAST OR GROUTED INTO CONCRETE FLOOR (SEE TABLE BELOW).
4. MINIMUM 1" DEPTH HILTI CP 618 FIRESTOP PUTTY STICK APPLIED AROUND SINGLE CABLE OR CABLE BUNDLE. (SEE NOTE BELOW).

MAX. DIA. OF CABLE BUNDLE	PRODUCT DESCRIPTION
2"	CP 680 75/2.5"
4-1/2"	CP 680 110/4"
6-1/2"	CP 680 160/6"

NOTE: AS AN ALTERNATE TO HILTI CP 618 FIRESTOP PUTTY STICK, MINIMUM 4" THICKNESS MINERAL WOOL (MIN. 4 PCF DENSITY) MAY BE TIGHTLY PACKED INTO HILTI CP 680, FLUSH WITH TOP SURFACE OF DEVICE.

UL/cUL SYSTEM NO. CAJ3095
SINGLE OR MULTIPLE CABLES THROUGH CONCRETE FLOOR/WALL OR BLOCK WALL
F-RATING = 3-HR.
T-RATING = 0-HR, 1/2-HR, & 3/4-HR.
(SEE U.L. FIRE RESISTANCE DIRECTORY VOL. 2)
TOP VIEW SECTION A-A

1. CONCRETE FLOOR OR WALL ASSEMBLY (3-HR FIRE-RATING):
A. LIGHTWEIGHT OR NORMAL WEIGHT CONCRETE FLOOR (MIN. 2-1/2" THICK).
B. LIGHTWEIGHT OR NORMAL WEIGHT CONCRETE WALL (MIN. 3" THICK).
C. ANY UL/CUL CLASSIFIED CONCRETE BLOCK WALL.
2. OPTIONAL: MAXIMUM 6" NOMINAL DIAMETER STEEL PIPE SLEEVE (SCHEDULE 10 OR HEAVIER).
3. MAXIMUM 4" DIAMETER CABLE BUNDLE TO BE A COMBINATION OF ANY OF THE FOLLOWING:
A. MAXIMUM 300 PAIR NO. 24 AWG TELEPHONE CABLE WITH PVC JACKET.
B. MAXIMUM 500 KCMIL POWER CABLE WITH PVC JACKET.
C. MAXIMUM 7/8" NO. 12 AWG POWER CABLE WITH PVC JACKET.
D. MAXIMUM (24 FIBER) 1/2" DIAMETER FIBER-OPTIC CABLE.
E. MAXIMUM 3/4" NO. 12 AWG METAL-CLAD CABLE.
4. MINIMUM 2" THICKNESS MINERAL WOOL (MIN. 4 PCF DENSITY) TIGHTLY PACKED.
5. MINIMUM 1/2" DEPTH HILTI FS-ONE INTUMESCENT FIRESTOP SEALANT.

NOTES: 1. MAXIMUM DIAMETER OF OPENING = 6".
2. CABLES TO FILL MINIMUM 25%, TO MAXIMUM 45% OF CROSS-SECTIONAL AREA OF OPENING.
3. STEEL FLOOR UNIT/FLOOR ASSEMBLY (NOT SHOWN)-THE FLOOR ASSEMBLY MAY ALSO CONSIST OF MINIMUM 2-1/2" CONCRETE OVER (1-1/2" TO 3" DEEP) FLUTED METAL DECK.
4. MINIMUM 1/2" DEPTH HILTI FS-ONE INTUMESCENT FIRESTOP SEALANT IS REQUIRED ON BOTH SIDES OF A WALL.

UL/cUL SYSTEM NO. CAJ4035
CABLE TRAY THROUGH CONCRETE FLOOR/WALL OR BLOCK WALL
F-RATING = 3-HR.
T-RATING = 0-HR.

1. CONCRETE FLOOR OR WALL ASSEMBLY (3-HR. FIRE-RATING):
A. LIGHTWEIGHT OR NORMAL WEIGHT CONCRETE FLOOR OR WALL (MIN. 4-1/2" THICK).
B. ANY UL/CUL CLASSIFIED CONCRETE BLOCK WALL.
2. MAXIMUM 24"x4" ALUMINUM OR STEEL OPEN LADDER CABLE TRAY. (SEE NOTE NO. 4 BELOW)
3. CABLES TO BE A COMBINATION OF ANY OF THE FOLLOWING:
A. MAXIMUM 300 PAIR NO. 24 AWG TELEPHONE CABLE.
B. MAXIMUM 500 KCMIL SINGLE CONDUCTOR POWER CABLE.
C. MAXIMUM (24 FIBER) 1/2" DIAMETER FIBER-OPTIC CABLE.
D. MAXIMUM 3/4" NO. 12 AWG METAL CLAD CABLE.
4. HILTI FS 657 FIRE BLOCK (2" THICK x 8" WIDE x 5" DEEP, REF: TOP VIEW).

NOTES: 1. MAXIMUM AREA OF OPENING = 270 SQUARE INCHES, WITH A MAXIMUM DIMENSION OF 30 INCHES.
2. ANNUAL SPACE = MINIMUM 1", MAXIMUM 4".
3. APPLY HILTI FS-ONE INTUMESCENT FIRESTOP SEALANT INTO INTERSTICES OF CABLES, BETWEEN CABLES AND CABLE TRAY, AND ANY VOIDS TO TO MAXIMUM EXTENT POSSIBLE.
4. MAXIMUM AREA OF CABLES SHALL BE 40% OF CROSS-SECTIONAL AREA OF CABLE TRAY.

UL/cUL SYSTEM NO. F-A-5015
INSULATED METAL PIPE THROUGH CONCRETE FLOOR OR CONCRETE OVER METAL DECKING
F-RATING = 2-HR.
T-RATING = 1/2-HR.

1. CONCRETE FLOOR ASSEMBLY (2-HR. FIRE-RATING) :
A. LIGHTWEIGHT OR NORMAL WEIGHT CONCRETE FLOOR (MIN. 2-1/2" THICK).
B. STEEL FLOOR UNIT/FLOOR ASSEMBLY - NORMAL WEIGHT CONCRETE FLOOR (MIN. 2-1/2" THICK) OVER METAL DECKING.
2. PENETRATING ITEM TO BE ONE OF THE FOLLOWING (SEE TABLE BELOW) :
A. MAXIMUM 4" NOMINAL DIAMETER STEEL PIPE (SCHEDULE 10 OR HEAVIER).
B. MAXIMUM 4" NOMINAL DIAMETER COPPER PIPE.
3. NOMINAL 3/4" THICK AB/PVC FLEXIBLE FOAM PIPE INSULATION.
4. HILTI CP 680 CAST-IN FIRESTOP DEVICE CAST OR GROUTED INTO CONCRETE FLOOR (SEE TABLE BELOW).

NOM. PIPE DIAMETER	AB/PVC THICKNESS	PRODUCT DESCRIPTION
1"	3/4"	CP680 75/2.5"
2"	3/4"	CP680 110/4"
4"	3/4"	CP680 160/6"

NOTE: FOR CONCRETE FLOOR OVER METAL DECKING APPLICATIONS, A CP 680 METAL DECK ADAPTER IS REQUIRED.

UL/cUL SYSTEM NO. F-A-5016
INSULATED METAL PIPE THROUGH CONCRETE FLOOR OR CONCRETE OVER METAL DECKING
F-RATING = 3-HR.
T-RATING = 3/4-HR, AND 1-HR.

1. CONCRETE FLOOR ASSEMBLY (3-HR. FIRE-RATING) :
A. LIGHTWEIGHT OR NORMAL WEIGHT CONCRETE FLOOR (MIN. 4-1/2" THICK).
B. STEEL FLOOR UNIT/FLOOR ASSEMBLY - NORMAL WEIGHT CONCRETE FLOOR (MIN. 4-1/2" THICK) OVER METAL DECKING.
2. PENETRATING ITEM TO BE ONE OF THE FOLLOWING (SEE TABLE BELOW) :
A. MAXIMUM 4" NOMINAL DIAMETER STEEL PIPE (SCHEDULE 10 OR HEAVIER).
B. MAXIMUM 4" NOMINAL DIAMETER COPPER PIPE.
3. NOMINAL 3/4" THICK AB/PVC FLEXIBLE FOAM PIPE INSULATION.
4. HILTI CP 680 CAST-IN FIRESTOP DEVICE CAST OR GROUTED INTO CONCRETE FLOOR (SEE TABLE BELOW).

NOM. PIPE DIAMETER	AB/PVC THICKNESS	PRODUCT DESCRIPTION
2"	3/4"	CP680 110/4"
4"	3/4"	CP680 160/6"

NOTE: FOR CONCRETE FLOOR OVER METAL DECKING APPLICATIONS, A CP 680 METAL DECK ADAPTER IS REQUIRED.

UL/cUL SYSTEM NO. W-L-4034
CABLE TRAY THROUGH 1-HR. OR 2-HR. GYPSUM WALL ASSEMBLY
F-RATING = 1-HR. OR 2-HR.
T-RATING = 0-HR.

1. GYPSUM WALL ASSEMBLY (UL/CUL CLASSIFIED U400 SERIES) (1-HR. OR 2-HR. FIRE-RATING) (2-HR. SHOWN).
2. OPENING TO BE "FRAMED OUT" WITH LIGHTGAGE STEEL STUDS (MIN. 3-1/2" WIDE).
3. ALUMINUM OPEN LADDER CABLE TRAY (MAXIMUM SIZE : 24" x 4").
4. CABLES TO CONSIST OF THE FOLLOWING :
A. MAXIMUM 300 PAIR NO. 24 AWG TELEPHONE CABLE.
B. MAXIMUM 500 KCMIL SINGLE CONDUCTOR POWER CABLE.
C. MAXIMUM 3/8" DIAMETER FIBER-OPTIC CABLE.
D. MAXIMUM 5/8" NO. 12 AWG METAL-CLAD CABLE.
5. HILTI CP 620 FIRE FOAM INSTALLED FLUSH WITH BOTH SURFACES OF THE WALL :
A. MINIMUM 4-3/4" THICKNESS, FOR A 1-HR. FIRE-RATING.
B. MINIMUM 6" THICKNESS, FOR A 2-HR. FIRE-RATING.

NOTES: 1. MAXIMUM SIZE OF OPENING = 30" x 9".
2. ANNUAL SPACE = MINIMUM 0", MAXIMUM 5".
3. MAXIMUM AREA OF CABLES SHALL BE 45% OF CROSS-SECTIONAL AREA OF CABLE TRAY.
4. OPTIONAL - NOT SHOWN. HILTI FS 657 FIRE BLOCKS (CENTERED WITHIN WALL ASSEMBLY) MAY BE APPLIED IN A SINGLE LAYER ABOVE CABLES WITHIN CABLE TRAY (2" THICK x 8" WIDE x 5" DEEP).

UL/cUL SYSTEM NO. W-L-3065
CABLE BUNDLE THROUGH 1-HR. OR 2-HR. GYPSUM WALL ASSEMBLY
F-RATING = 1-HR. OR 2-HR.
T-RATING = 0-HR.

1. GYPSUM WALL ASSEMBLY (UL/CUL CLASSIFIED U300 OR U400 SERIES) (1-HR. OR 2-HR. FIRE-RATING) (2-HR. SHOWN).
2. (NOT SHOWN). WOOD STUDS TO CONSIST OF NOMINAL 2" x 4" LUMBER. STEEL STUDS TO BE MINIMUM 2-1/2" WIDE.
3. OPTIONAL : MAXIMUM 4" NOMINAL DIAMETER STEEL PIPE SLEEVE (SCHEDULE 5 OR HEAVIER) (SEE NOTE NO. 4 BELOW).
4. CABLE BUNDLE TO CONSIST OF ANY COMBINATION OF THE FOLLOWING :
A. MAXIMUM 7/8" NO. 12 AWG CABLE.
B. MAXIMUM 25 PAIR NO. 24 AWG TELEPHONE CABLE.
C. RG 59 COAXIAL CABLE.
D. MAXIMUM 3/8" NO. 8 AWG METAL-CLAD CABLE.
E. MAXIMUM 3/4" (WITH GROUND) NO. 8 AWG COPPER CONDUCTOR CABLE (ROMEX).
F. MAXIMUM 5/8" DIAMETER FIBER-OPTIC CABLE.
5. MINIMUM 5/8" DEPTH HILTI FS-ONE INTUMESCENT FIRESTOP SEALANT, CP 6015 ELASTOMERIC FIRESTOP SEALANT, OR CP 606 FLEXIBLE FIRESTOP SEALANT.
6. SEE NOTE NO. 4 BELOW.

NOTES: 1. MAXIMUM SIZE OF OPENING = 4".
2. ANNUAL SPACE = MINIMUM 1/4", MAXIMUM 3/4".
3. CABLES TO FILL MAXIMUM 45% OF CROSS-SECTIONAL AREA OF OPENING.
4. STEEL SLEEVE MAY BE FLUSH WITH WALL SURFACE OR EXTEND UP TO 18" BEYOND WALL SURFACE. WHEN SLEEVE IS EXTENDED BEYOND ONE OR BOTH SIDES OF WALL, APPLY MINIMUM 1/2" BEAD HILTI FS-ONE INTUMESCENT FIRESTOP SEALANT, CP 6015 ELASTOMERIC FIRESTOP SEALANT, OR CP 606 FLEXIBLE FIRESTOP SEALANT TO WALL/SLEEVE INTERFACE.

UL/cUL SYSTEM NO. CAJ1226
METAL PIPE THROUGH A SLEEVE IN CONCRETE FLOOR/WALL OR BLOCK WALL
F-RATING = 3-HR.
T-RATING = 0-HR.
L RATING AT AMBIENT = LESS THAN 1 CFM/SQ. FT.
L RATING AT 400°F = 4 CFM/SQ. FT.

1. CONCRETE FLOOR OR WALL ASSEMBLY (3-HR FIRE-RATING):
A. LIGHTWEIGHT OR NORMAL WEIGHT CONCRETE FLOOR OR WALL (MIN. 4-1/2" THICK).
B. ANY UL/CUL CLASSIFIED CONCRETE BLOCK WALL.
2. OPTIONAL: MAXIMUM 32" NOMINAL DIAMETER STEEL PIPE SLEEVE (SCHEDULE 40 OR HEAVIER).
3. PENETRATING ITEM TO BE ONE OF THE FOLLOWING:
A. MAXIMUM 30" NOMINAL DIAMETER STEEL PIPE (SCHEDULE 10 OR HEAVIER).
B. MAXIMUM 30" NOMINAL DIAMETER CAST IRON PIPE.
C. MAXIMUM 6" NOMINAL DIAMETER COPPER PIPE.
D. MAXIMUM 6" NOMINAL DIAMETER STEEL CONDUIT.
E. MAXIMUM 4" NOMINAL DIAMETER ENT.
4. MINIMUM 4" THICKNESS MINERAL WOOL (MIN. 4 PCF DENSITY) TIGHTLY PACKED.
5. MINIMUM 1/4" DEPTH HILTI FS-ONE INTUMESCENT FIRESTOP SEALANT.
6. MINIMUM 1/4" CROWN HILTI FS-ONE INTUMESCENT FIRESTOP SEALANT APPLIED AT POINT OF CONTACT.

NOTES: 1. MAXIMUM DIAMETER OF OPENING = 32".
2. ANNUAL SPACE = MINIMUM 0", MAXIMUM 1-7/8".
3. MINIMUM 1/4" DEPTH HILTI FS-ONE INTUMESCENT FIRESTOP SEALANT IS REQUIRED ON BOTH SIDES OF A WALL ASSEMBLY.

U.L. SYSTEM NO. WL2075
ENT THROUGH 1-HR. OR 2-HR. GYPSUM WALL ASSEMBLY
F-RATING = 1-HR. AND 2-HR.
T-RATING = 0-HR. AND 2-HR. (FOR 1-HR. AND 2-HR. WALLS, RESPECTIVELY)
L RATING AT AMBIENT = LESS THAN 1 CFM/SQ. FT.
L RATING AT 400°F = 4 CFM/SQ. FT.

1. GYPSUM WALL ASSEMBLY (U.L. CLASSIFIED U300 OR U400 SERIES) (1-HR OR 2-HR FIRE-RATING) (2-HR SHOWN).
2. OPTIONAL: MAXIMUM 4" NOMINAL DIAMETER STEEL PIPE SLEEVE (SCHEDULE 40 OR THINNER).
3. MAXIMUM 2" NOMINAL DIAMETER ENT.
4. HILTI FS-ONE INTUMESCENT FIRESTOP SEALANT:
A. MINIMUM 5/8" DEPTH, FOR A 1-HR FIRE-RATING.
B. MINIMUM 1-1/4" DEPTH, FOR A 2-HR FIRE-RATING.

NOTES: 1. MAXIMUM DIAMETER OF OPENING = 4".
2. ANNUAL SPACE = 3/4".

UL/cUL SYSTEM NO. F-A-1017
METAL PIPE THROUGH CONCRETE FLOOR OR CONCRETE OVER METAL DECKING
F-RATING = 3-HR.
T-RATING = 0-HR.

1. CONCRETE FLOOR ASSEMBLY (3-HR. FIRE-RATING) :
A. LIGHTWEIGHT OR NORMAL WEIGHT CONCRETE FLOOR (MIN. 4-1/2" THICK).
B. STEEL FLOOR UNIT/FLOOR ASSEMBLY - NORMAL WEIGHT CONCRETE FLOOR (MIN. 4-1/2" THICK) OVER METAL DECKING.
2. PENETRATING ITEM TO BE ONE OF THE FOLLOWING :
A. MAXIMUM 6" NOMINAL DIAMETER STEEL PIPE (SCHEDULE 10 OR HEAVIER).
B. MAXIMUM 6" NOMINAL DIAMETER CAST IRON PIPE.
C. MAXIMUM 6" NOMINAL DIAMETER COPPER PIPE.
D. MAXIMUM 6" NOMINAL DIAMETER STEEL CONDUIT.
E. MAXIMUM 4" NOMINAL DIAMETER ENT.
3. HILTI CP 680 CAST-IN FIRESTOP DEVICE CAST OR GROUTED INTO CONCRETE FLOOR (SEE TABLE BELOW).

NOM. PIPE DIAMETER	PRODUCT DESCRIPTION
1-1/2" TO 2-1/2"	CP680 75/2.5"
3" TO 4"	CP680 110/4"
4" TO 6"	CP680 160/6"

NOTES: 1. FOR CONCRETE FLOOR OVER METAL DECKING APPLICATIONS, A CP 680 CAST-IN FIRESTOP DEVICE METAL DECK ADAPTER IS REQUIRED.
2. WHEN PIPE DIAMETER IS SMALLER THAN INDICATED ABOVE, A MIN. 1" THICKNESS HILTI CP 618 FIRESTOP PUTTY STICK SHALL BE APPLIED BETWEEN THE PIPE AND PERIPHERY OF HILTI CP 680 CAST-IN FIRESTOP DEVICE, FLUSH WITH TOP SURFACE OF DEVICE.
3. AS AN ALTERNATE TO HILTI CP 618, MINIMUM 4" THICKNESS MINERAL WOOL (MIN. 4 PCF DENSITY) MAY BE TIGHTLY PACKED INTO HILTI CP 680, FLUSH WITH TOP SURFACE OF DEVICE.

UL/cUL SYSTEM NO. W-L-1054
METAL PIPE THROUGH 1-HR. OR 2-HR. GYPSUM WALL ASSEMBLY
F-RATING = 1-HR. OR 2-HR.
T-RATING = 0-HR.
L-RATING AT AMBIENT = LESS THAN 1 CFM/SQ. FT.
L-RATING AT 400°F = 4 CFM/SQ. FT.

1. GYPSUM WALL ASSEMBLY (UL/CUL CLASSIFIED U300 OR U400 SERIES) (1-HR. OR 2-HR. FIRE-RATING) (2-HR. SHOWN).
2. (NOT SHOWN). WOOD STUDS TO CONSIST OF NOMINAL 2" x 4" LUMBER. STEEL STUDS TO BE MINIMUM 2-1/2" WIDE.
3. PENETRATING ITEM TO BE ONE OF THE FOLLOWING :
A. MAXIMUM 30" DIAMETER STEEL PIPE (SCHEDULE 10 OR HEAVIER).
B. MAXIMUM 30" DIAMETER CAST IRON PIPE.
C. MAXIMUM 6" NOMINAL DIAMETER COPPER PIPE.
D. MAXIMUM 6" NOMINAL DIAMETER STEEL CONDUIT.
E. MAXIMUM 4" NOMINAL DIAMETER ENT.
4. HILTI FS-ONE HIGH PERFORMANCE INTUMESCENT FIRESTOP SEALANT :
A. MINIMUM 5/8" FOR A 1-HR. FIRE-RATING.
B. MINIMUM 1-1/4" DEPTH, FOR A 2-HR. FIRE-RATING.
5. MINIMUM 1/2" BEAD HILTI FS-ONE HIGH PERFORMANCE INTUMESCENT FIRESTOP SEALANT AT POINT OF CONTACT.

NOTES: 1. MAXIMUM DIAMETER OF OPENING :
A. 32-1/4" FOR STEEL STUD WALLS.
B. 14-1/2" FOR WOOD STUD WALLS.
2. ANNUAL SPACE = MINIMUM 0", MAXIMUM 2-1/2".

UL/cUL SYSTEM NO. CAJ6017
ELECTRICAL BUSWAY THROUGH CONCRETE FLOOR/WALL OR BLOCK WALL
F-RATING = 3-HR.
T-RATING = 0-HR.

1. CONCRETE FLOOR OR WALL ASSEMBLY (3-HR FIRE-RATING):
A. LIGHTWEIGHT OR NORMAL WEIGHT CONCRETE FLOOR OR WALL (MIN. 4-1/2" THICK).
B. ANY UL/CUL CLASSIFIED CONCRETE BLOCK WALL.
2. ELECTRICAL BUSWAY (NOMINAL 26" WIDE BY 6" DEEP, OR SMALLER) ("I" SHAPED STEEL ENCLOSURE CONTAINING FACTORY MOUNTED ALUMINUM BARS RATED FOR 600V OR 4000A).
3. MINIMUM 3-1/2" THICKNESS MINERAL WOOL (MIN. 4 PCF DENSITY) TIGHTLY PACKED.
4. MINIMUM 1" DEPTH HILTI FS-ONE INTUMESCENT FIRESTOP SEALANT.

NOTES: 1. MAXIMUM AREA OF OPENING IS 224 SQUARE INCHES WITH A MAXIMUM DIMENSION OF 28 INCHES.
2. MINIMUM 1" DEPTH HILTI FS-ONE INTUMESCENT FIRESTOP SEALANT IS REQUIRED ON BOTH SIDES OF A WALL.

UL/cUL SYSTEM NO. CAJ8056
MULTIPLE PENETRATING ITEMS THROUGH CONCRETE FLOOR/WALL OR BLOCK WALL
F-RATING = 3-HR. L RATING AT AMBIENT = 5 CFM/SQ. FT.
T-RATING = 0-HR. L RATING AT 400°F = 2 CFM/SQ. FT.

1. CONCRETE FLOOR OR WALL ASSEMBLY (3-HR FIRE-RATING):
A. LIGHTWEIGHT OR NORMAL WEIGHT CONCRETE FLOOR OR WALL (MIN. 4-1/2" THICK).
B. ANY UL/CUL CLASSIFIED CONCRETE BLOCK WALL.
2. MAXIMUM 18" x 6" ALUMINUM OR STEEL OPEN LADDER CABLE TRAY.
3. ANY COMBINATION OF THE FOLLOWING CABLES MAY BE USED WITHIN THE CABLE TRAY (SEE NOTE NO. 4 BELOW):
A. 7/8" NO. 12 AWG COPPER CONDUCTOR CABLE.
B. MAX. 500 KCMIL SINGLE CONDUCTOR CABLE.
C. MAX. 300 PAIR NO. 24 AWG TELEPHONE CABLE.
4. PENETRATING ITEMS TO BE ANY OF THE FOLLOWING: MAXIMUM 6" NOMINAL DIAMETER STEEL PIPE OR STEEL CONDUIT; MAXIMUM 6" NOMINAL DIAMETER CAST IRON PIPE; OR MAXIMUM 4" NOMINAL DIAMETER COPPER PIPE OR ENT.
5. MAXIMUM 1-1/2" GLASS FIBER INSULATION.
6. MAXIMUM 2" CABLE BUNDLE TO BE A COMBINATION OF ANY OF THE FOLLOWING:
A. 7/8" NO. 12 AWG CABLE. D. 3/4" NO. 8 ALUMINUM CLAD CABLE.
B. 25 PAIR NO. 24 AWG TELEPHONE CABLE. E. RG 62A COAXIAL CABLE.
C. ROMEX (22/C NO. 10 + GND). F. 24 FIBER-OPTIC CABLE (MAX. 1/2" DIA.).
7. HILTI FS 657 FIRE BLOCK (2" THICK x 8" WIDE x 5" DEEP, REF: TOP VIEW).

NOTES: 1. MAXIMUM AREA OF OPENING = 1296 SQUARE INCHES, WITH MAXIMUM DIMENSION OF 36 INCHES
2. ANNUAL SPACE FOR CABLE TRAY = MINIMUM 1-1/2", MAXIMUM 4-1/2".
3. ANNUAL SPACE FOR PIPE AND CABLE PENETRATIONS = MINIMUM 1", MAXIMUM 4-1/2".
4. MAXIMUM AREA OF CABLES EQUALS 30% OF CROSS-SECTIONAL AREA OF CABLE TRAY.
5. APPLY HILTI FS-ONE INTUMESCENT FIRESTOP SEALANT INTO INTERSTICES OF CABLES, BETWEEN CABLES AND CABLE TRAY, AND ANY VOIDS TO MAXIMUM EXTENT POSSIBLE.
6. WIRE MESH (NOT SHOWN), WHEN THE ANNUAL SPACE EXCEEDS 4-1/2", A NOMINAL 2 IN. SQ. NO. 16 SWG WIRE MESH SHALL BE USED TO KEEP THE HILTI FS 657 FIRE BLOCKS IN PLACE.

UL/cUL SYSTEM NO. W-L-8013
MULTIPLE PENETRATIONS THROUGH 1-HR. OR 2-HR. GYPSUM WALL ASSEMBLY
F-RATING = 1-HR. OR 2-HR. L-RATING AT AMBIENT = 5 CFM/SQ. FT.
T-RATING = 0-HR. L-RATING AT 400°F = 2 CFM/SQ. FT.

1. GYPSUM WALL ASSEMBLY (UL/CUL CLASSIFIED U300 OR U400 SERIES) (1-HR. OR 2-HR. FIRE-RATING) (2-HR. SHOWN).
2. (NOT SHOWN). WOOD STUDS TO CONSIST OF NOMINAL 2" x 4" LUMBER, STEEL STUDS TO BE MINIMUM 2-1/2" WIDE.
3. OPEN LADDER CABLE TRAY (MAXIMUM 18" x 6", STEEL OR ALUMINUM).
4. ANY OF THE FOLLOWING CABLES MAY BE USED WITH MAXIMUM 30% FILL OF CABLE TRAY :
A. MAXIMUM 350 KCMIL SINGLE CONDUCTOR POWER CABLE.
B. MAXIMUM 7/8" NO. 12 AWG COPPER CONDUCTOR CABLE.
C. MAXIMUM 100 PAIR NO. 24 AWG TELEPHONE CABLE.
5. MAX. 3" NOMINAL DIAMETER PVC PLASTIC PIPE (SCHEDULE 40) (CLOSED OR VENTED PIPING SYSTEM) (SEE NOTE NO. 1 BELOW).
6. MAXIMUM 1-1/2" DIAMETER CABLE BUNDLE TO CONSIST OF ANY OF THE FOLLOWING :
A. FIBER-OPTIC CABLE (24 FIBER). C. MAX. 25 PAIR NO. 24 AWG TELEPHONE CABLE.
B. RG 59 COAXIAL CABLE. D. MAX. 7/8" NO. 12 AWG COPPER CONDUCTOR.
7. HILTI FS 657 FIRE BLOCKS (2" THICK x 8" WIDE x 5" DEEP, REFERENCE : FRONT VIEW).

NOTES: 1. (NOT SHOWN). PENETRATING ITEMS MAY ALSO INCLUDE A MAX. 6" NOM. DIA. STEEL PIPE, MAX. 6" NOM. DIA. STEEL CONDUIT; MAX. 4" NOM. DIA. COPPER PIPE, OR MAX. 4" NOM. DIA. ENT.
2. (NOT SHOWN): MAX. 1-1/2" GLASS-FIBER INSULATION MAY BE USED ON ANY OR ALL METALLIC PIPES.
3. ANNUAL SPACE = MINIMUM 1", MAXIMUM 9-1/4".
4. APPLY HILTI FS-ONE INTUMESCENT FIRESTOP SEALANT IN ANY VOID THAT MAY EXIST (AROUND PENETRANTS, INTO INTERSTICES OF CABLES, BETWEEN CABLES AND CABLE TRAY, OR BETWEEN FIRE BLOCKS) TO MAXIMUM EXTENT POSSIBLE.

Notes:

- Refer to the specifications. For Quality Control requirements, refer to the Quality Control portion of the specification.
- Details shown are typical details. If field conditions do not match requirements of typical details, approved alternate details shall be verified. Field conditions and dimensions need to be verified for compliance with the details, including but not limited to the following:
2.a. Minimum and maximum Width of Joints
2.b. Type and thickness of fire-rated construction. The minimum assembly rating of the firestop assembly shall meet or exceed the highest rating of the adjacent construction.
- If alternate details matching the field conditions are not available, manufacturer's engineering judgment drawings are acceptable. Drawings shall follow the International Firestop Council (IFC) Guidelines for Evaluating Firestop Systems Engineering Judgments.
- References:
4.a. 2001 Underwriter's Laboratories Fire Resistance Directory, Volumes 1 & 2
4.b. NFPA 101 Life Safety Code
4.c. 2001 Directory of Listed Materials and assemblies, Omega Polite Laboratories
4.d. NFPA 70 - National Electric Code
4.e. All governing local and regional building codes
5. Firestop System installation must meet requirements of ASTM E-814 (UL 1479) tested assemblies that provide a fire rating equal to that of construction being penetrated.
6. All rated through-penetration assemblies shall be prominently labeled with the following information:
6.a. ATTENTION: Fire Rated Assembly
6.b. UL System #
6.c. Product(s) used
6.d. Hourly Rating (F-Rating)
6.e. Installation Date
7. For outlet boxes requiring protection, use only Wall Opening Protective Materials, category CLV as classified by Underwriter's Laboratories, Fire Resistance Directory (Volume 1.)


CHECKED BY: LR. DRAWN BY: C.V.

CONSULTANT INFO:




NEW ELEMENTARY SCHOOL (K-5)
VENETIAN PARC WEST
SOUTHWEST 157th AVENUE and 174th STREET
MIAMI, FL. 33187
MDCPS PROJECT No. 01892600

KEY PLAN

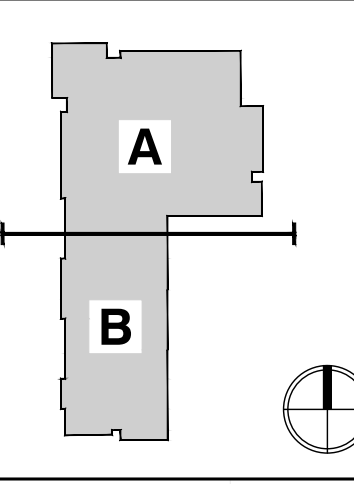

CONSULTANT INFO:

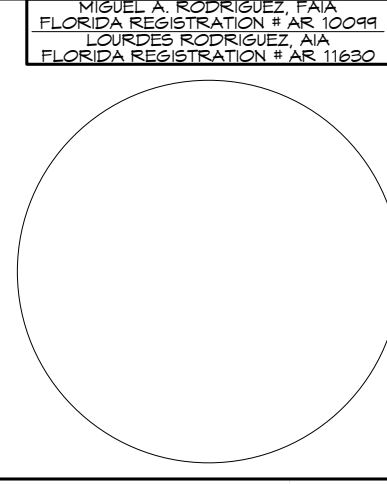

RODRIGUEZ ARCHITECTS INCORPORATED
2121 PONCE DE LEON BLVD. STE 1010
CORAL GABLES, FL. 33134
TEL: (305) 448-3373
FAX: (305) 448-3374
A A C - - 0 0 1 9 3 3


RAI

REVISIONS:

REVISIONS:


NO.	DESCRIPTION

DRAWING TITLE:
FIRESTOP PENETRATION DETAILS
SCALE: AS NOTED
ISSUE DATE: 12/16/19
PROJECT NO: 1906
SHEET: A-661

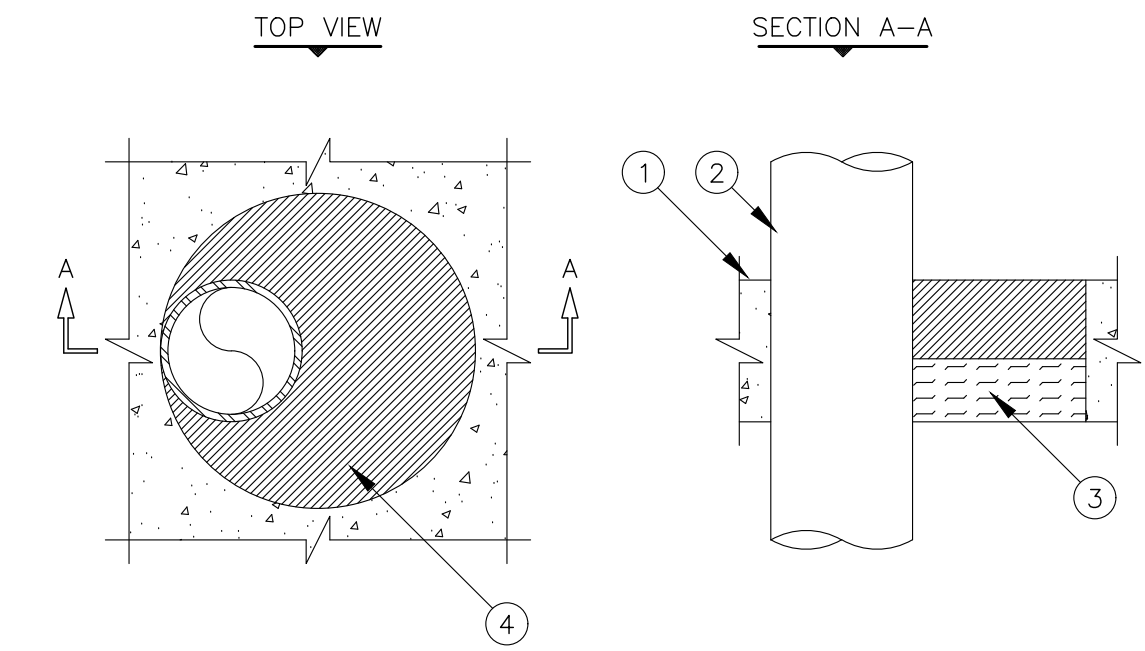

- CONCRETE FLOOR OR WALL ASSEMBLY (3-HR. FIRE-RATING) :
 - LIGHTWEIGHT OR NORMAL WEIGHT CONCRETE FLOOR (MIN. 4-1/2" THICK).
 - LIGHTWEIGHT OR NORMAL WEIGHT CONCRETE WALL (MIN. 7" THICK).
 - ANY UL/ULC CLASSIFIED CONCRETE BLOCK WALL.
- PENETRATING ITEM TO BE ONE OF THE FOLLOWING :
 - MAXIMUM 4" NOMINAL DIAMETER STEEL PIPE (SCHEDULE 10 OR HEAVIER).
 - MAXIMUM 4" NOMINAL DIAMETER CAST IRON PIPE.
 - MAXIMUM 4" NOMINAL DIAMETER COPPER PIPE.
 - MAXIMUM 4" NOMINAL DIAMETER EMT OR STEEL CONDUIT.
- MINIMUM 2" THICKNESS MINERAL WOOL (MIN. 4 PCF DENSITY) TIGHTLY PACKED.
- MINIMUM 2-1/2" DEPTH HILTI CP 620 FIRE FOAM, FLUSH WITH TOP SURFACE OF FLOOR.


NOTES: 1. MAXIMUM DIAMETER OF OPENING = 10".
2. ANNUAL SPACE = MINIMUM 0", MAXIMUM 5-7/8".
3. MINIMUM 2-1/2" DEPTH HILTI CP 620 FIRE FOAM IS REQUIRED ON BOTH SIDES OF A WALL ASSEMBLY.

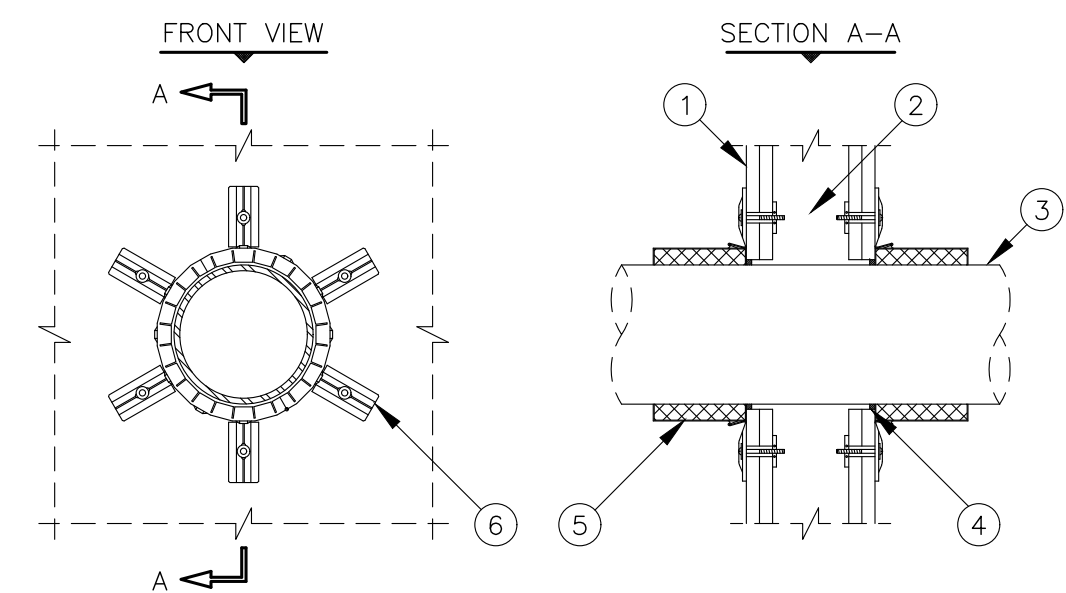

- GYPSUM WALL ASSEMBLY (U.L. CLASSIFIED U300 OR U400 SERIES) (1-HR. OR 2-HR. FIRE-RATING) (2-HR. SHOWN).
- (NOT SHOWN). WOOD STUDS TO CONSIST OF NOMINAL 2" x 4" LUMBER. STEEL STUDS TO BE MINIMUM 2-1/2" WIDE.
- PENETRATING ITEM TO BE ONE OF THE FOLLOWING (SEE NOTE NO. 3 BELOW) :
 - MAXIMUM 6" NOMINAL DIAMETER PVC PLASTIC PIPE (CELLULAR OR SOLID CORE).
 - MAXIMUM 6" NOMINAL DIAMETER ABS PLASTIC PIPE (CELLULAR OR SOLID CORE).
 - MAXIMUM 6" NOMINAL DIAMETER FRPP PLASTIC PIPE.
 - MAXIMUM 6" NOMINAL DIAMETER CPVC PLASTIC PIPE.
- SEE NOTE NO. 1 BELOW.
- HILTI CP 642 OR HILTI CP 643 FIRESTOP COLLAR (SEE TABLE BELOW).
- FASTEN EACH MOUNTING TAB TO WALL ASSEMBLY WITH APPROPRIATE HILTI ANCHORS.

NOM. PIPE DIA.	PRODUCT DESCRIPTION	NO. OF MOUNTING TABS	MAX. HOLE SIZE
1-1/2"	CP 643 50/1.5"	2	2-1/8"
2"	CP 643 63/2"	2	2-5/8"
3"	CP 643 90/3"	3	4"
4"	CP 643 110/4"	3	5"
6"	CP 642 160/6"	6	7"


NOTES: 1. TO IMPEDE COLD SMOKE, PROVIDE 1/4" DEPTH HILTI FS-ONE INTUMESCENT FIRE-STOP SEALANT IN ANNUAL SPACE AROUND PLASTIC PIPE.
2. ANNUAL SPACE = MINIMUM 0", MAXIMUM 1-1/2".
3. CLOSED OR VENTED PIPING SYSTEMS.
(PVC, ABS, FRPP = SCH. 40, CPVC = SDR 17).

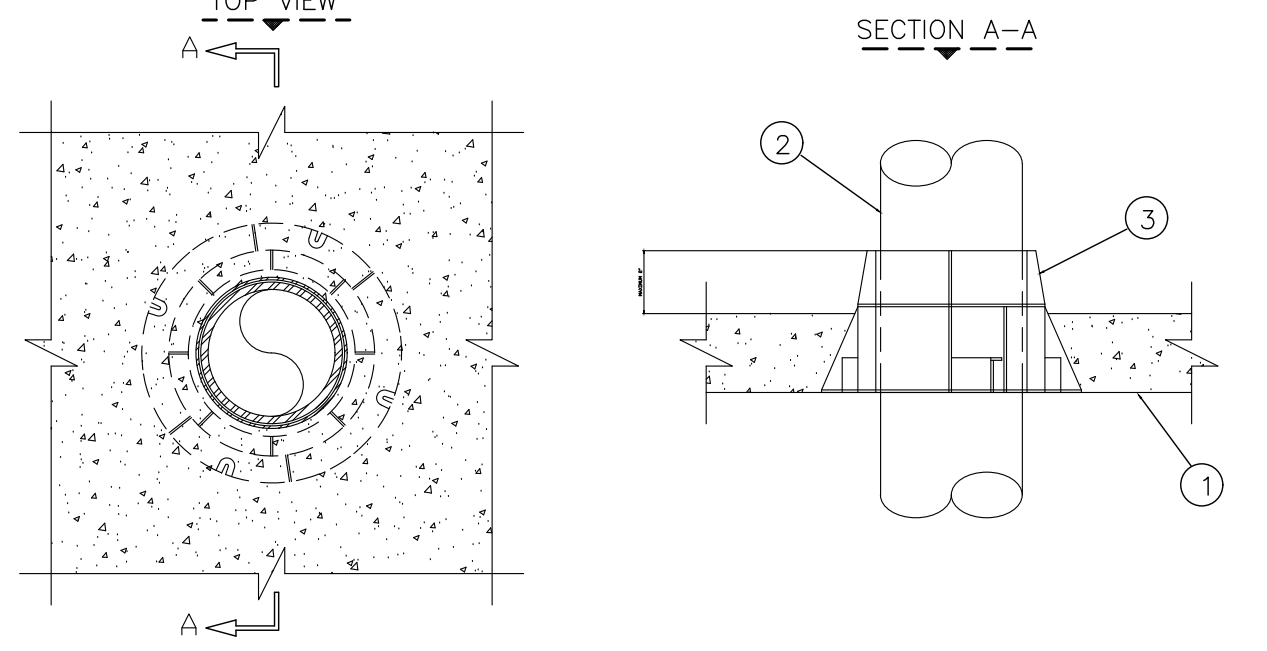

- CONCRETE FLOOR ASSEMBLY (2-HR. FIRE-RATING) :
 - LIGHTWEIGHT OR NORMAL WEIGHT CONCRETE FLOOR (MIN. 2-1/2" THICK).
 - STEEL FLOOR UNIT/FLOOR ASSEMBLY - NORMAL WEIGHT CONCRETE FLOOR (MIN. 2-1/2" THICK) OVER METAL DECKING.
- PENETRATING ITEM TO BE ONE OF THE FOLLOWING (SEE TABLE BELOW) :
 - MAXIMUM 6" NOMINAL DIAMETER PVC PLASTIC PIPE (CELLULAR AND SOLID CORE).
 - MAXIMUM 6" NOMINAL DIAMETER CPVC PLASTIC PIPE.
- HILTI CP 680 CAST-IN FIRESTOP DEVICE, CAST OR GROUTED INTO CONCRETE FLOOR (SEE TABLE BELOW).


NOM. PIPE DIAMETER	TYPE OF PIPE	PRODUCT DESCRIPTION
1-1/2" TO 2"	PVC, CPVC	CP680 75/2.5"
3" TO 4"	PVC, CPVC	CP680 110/4"
6"	PVC, CPVC	CP680 160/6"

NOTES: 1. CLOSED OR VENTED PIPING SYSTEMS (PVC = SCHEDULE 40, CPVC = SDR 17).
2. FOR CONCRETE FLOOR OVER METAL DECKING APPLICATIONS, A CP 680 METAL DECK ADAPTER IS REQUIRED.
3. PLASTIC PIPES USED IN CONJUNCTION WITH HILTI CP 680 110/4" AND CP 680 160/6" MUST BE INSTALLED FROM THE TOP SIDE OF THE ASSEMBLY.

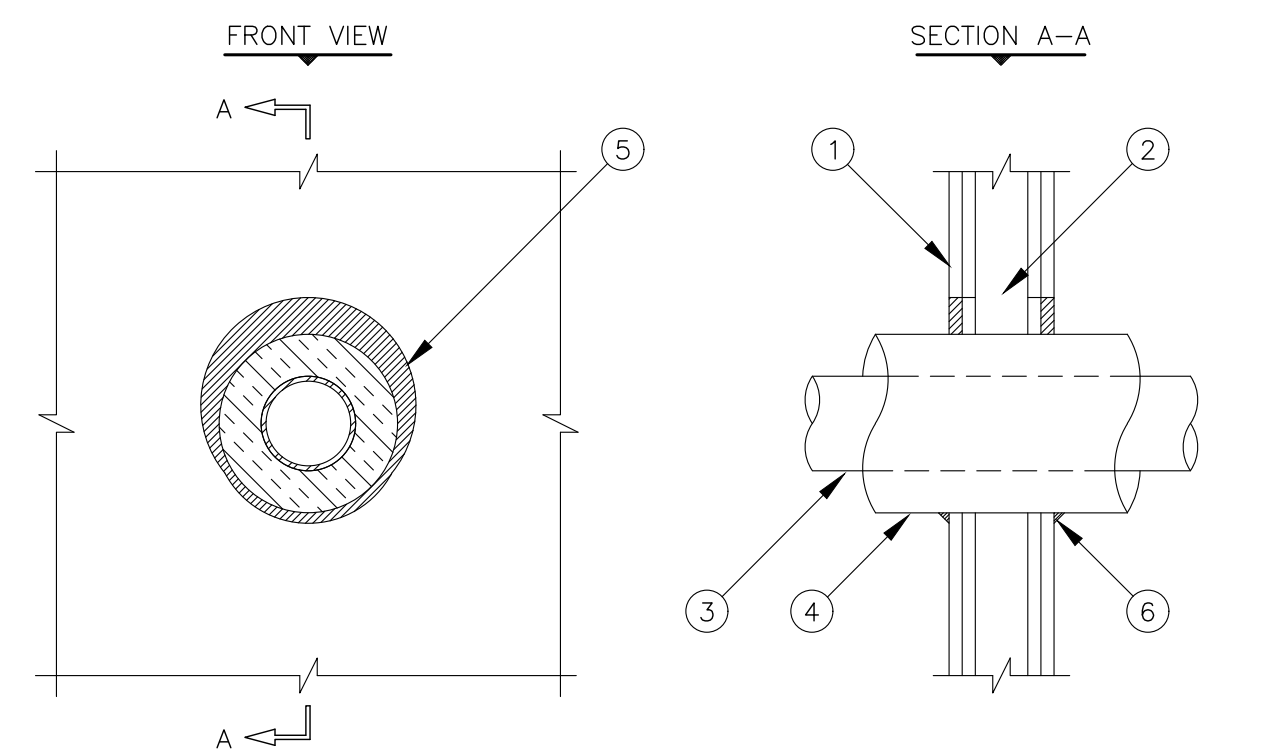


- GYPSUM WALL ASSEMBLY (UL/ULC CLASSIFIED U300 OR U400 SERIES) (1-HR. OR 2-HR. FIRE-RATING) (2-HR. SHOWN).
- (NOT SHOWN). WOOD STUDS TO CONSIST OF NOMINAL 2" x 4" LUMBER. STEEL STUDS TO BE MINIMUM 2-1/2" WIDE.
- PENETRATING ITEM TO BE ONE OF THE FOLLOWING :
 - MAXIMUM 12" NOMINAL DIAMETER STEEL PIPE (SCHEDULE 20 OR HEAVIER).
 - MAXIMUM 6" NOMINAL DIAMETER COPPER PIPE.
 - MAXIMUM 4" NOMINAL DIAMETER STEEL CONDUIT.
 - MAXIMUM 4" NOMINAL DIAMETER EMT.
- MAXIMUM 2" THICK GLASS-FIBER PIPE INSULATION.
- MINIMUM 5/8" DEPTH HILTI FS-ONE HIGH PERFORMANCE INTUMESCENT FIRESTOP SEALANT.
- MINIMUM 1/2" BEAD HILTI FS-ONE HIGH PERFORMANCE INTUMESCENT FIRESTOP SEALANT AT POINT OF CONTACT.

NOTES: 1. MAXIMUM DIAMETER OF OPENING = 18".
2. ANNUAL SPACE = MINIMUM 0", MAXIMUM 1-7/8".

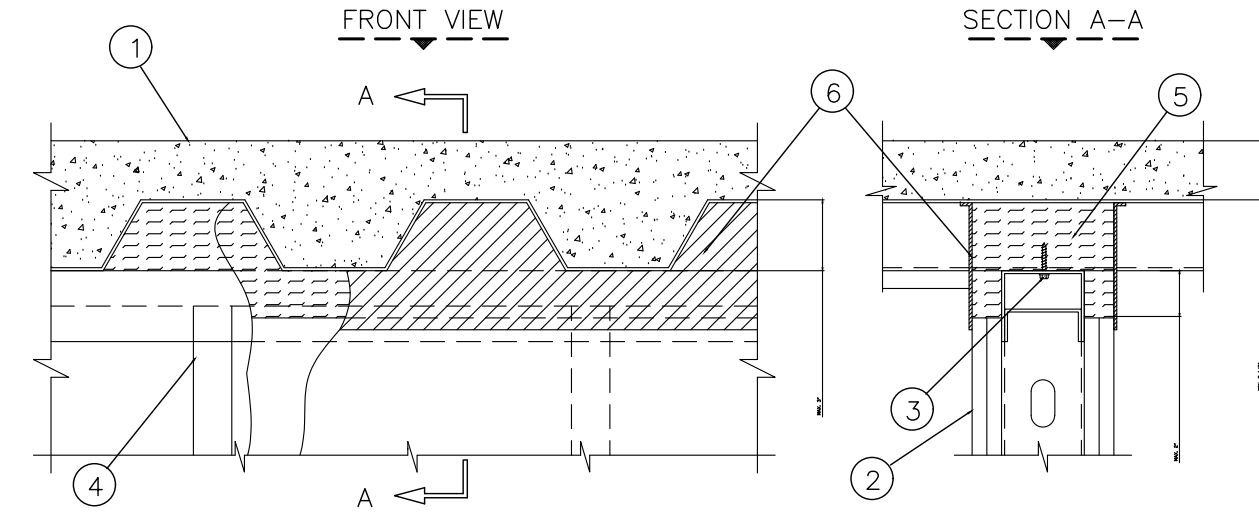


- LIGHTWEIGHT OR NORMAL WEIGHT CONCRETE FLOOR (MIN. 2-1/2" THICK) OVER METAL DECKING (1-HR. OR 2-HR. FIRE-RATING).
- GYPSUM WALL ASSEMBLY (UL/ULC CLASSIFIED U400 SERIES) (1-HR. OR 2-HR. FIRE-RATING).
- METAL DEFLECTION TRACK (MIN. 22 GA., 3" FLANGES) FASTENED TO UNDERSIDE OF THE DECK CEILING RUNNER (1" FLANGES) INSTALLED WITHIN THE U-SHAPED DEFLECTION CHANNEL WITH A 1-1/2" GAP MAINTAINED BETWEEN THE TOP OF THE CEILING RUNNER AND TOP OF DEFLECTION PLATE. (SEE NOTE NO. 3 BELOW).
- STEEL STUDS (MIN. 3-1/2" WIDE) CUT 1/2" OR 3/4" LESS IN LENGTH THAN ASSEMBLY HEIGHT, NESTING IN CEILING RUNNER WITHOUT ATTACHMENT.
- MINERAL WOOL (MIN. 4 PCF DENSITY) COMPRESSED 33 PERCENT AND INSERTED INTO FLUTES, FLUSH WITH WALL SURFACES.
- MINIMUM 1/8" (WET) THICKNESS HILTI CP 672 FIRESTOP JOINT SPRAY TO COMPLETELY COVER MINERAL WOOL AND TO OVERLAP A MINIMUM OF 1/2" ONTO GYPSUM AND METAL DECKING ON BOTH SIDES OF WALL ASSEMBLY.

NOTES: 1. STEEL FLOOR UNITS MAY BE SPRAYED WITH A MINIMUM 5/16" THICKNESS TO MAX. 1-3/4" THICKNESS OF UL CLASSIFIED MONOKOTE TYPE MK-6/HY FIREPROOFING MANUFACTURED BY W.R. GRACE.
2. WHEN THE STEEL DECK IS COATED WITH FIREPROOFING, HILTI CP 672 SHALL OVERLAP THE WALL A MINIMUM OF 1/2" AND OVERLAP THE FIREPROOFING A MIN. 2" ON BOTH SIDES OF WALL ASSEMBLY.
3. AS AN ALTERNATE TO CEILING RUNNER IN ITEM NO. 3, SLOTTED CEILING RUNNER, MANUFACTURED BY SLIPTRACK SYSTEMS, INC., OR VERTIRACK, MANUFACTURED BY THE STEEL NETWORK, INC., MAY BE USED. WHEN ALTERNATE CEILING TRACKS ARE USED, CONSULT THE UL FIRE RESISTANCE DIRECTORY FOR INSTALLATION INSTRUCTIONS.

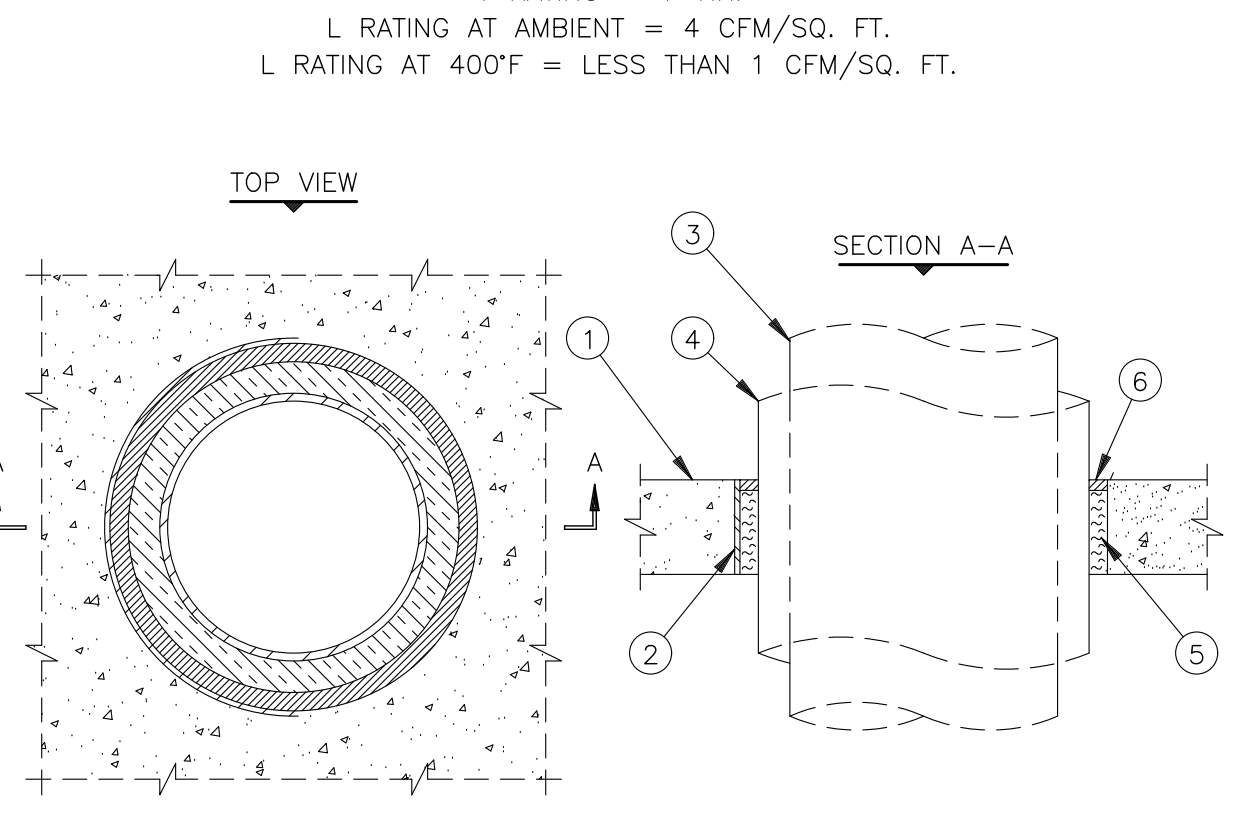


- CONCRETE FLOOR OR WALL ASSEMBLY (2-HR. FIRE-RATING):
 - LIGHTWEIGHT OR NORMAL WEIGHT CONCRETE FLOOR OR WALL (MINIMUM 4-1/2" THICK).
 - ANY UL/ULC CLASSIFIED CONCRETE BLOCK WALL.
- OPTIONAL: MAXIMUM 20" NOMINAL DIAMETER STEEL PIPE SLEEVE (SCHEDULE 10 OR HEAVIER).
- PENETRATING ITEM TO BE ONE OF THE FOLLOWING:
 - MAXIMUM 12" NOMINAL DIAMETER STEEL PIPE (SCHEDULE 10 OR HEAVIER).
 - MAXIMUM 6" NOMINAL DIAMETER COPPER PIPE.
- MAXIMUM 2" THICK GLASS FIBER INSULATION.
- MINIMUM 4" THICKNESS MINERAL WOOL (MIN. 4 PCF DENSITY) TIGHTLY PACKED.
- MINIMUM 1/2" DEPTH HILTI FS-ONE INTUMESCENT FIRESTOP SEALANT.

NOTES: 1. MAXIMUM DIAMETER OF OPENING = 20".
2. ANNUAL SPACE = MINIMUM 1/2", MAXIMUM 2-1/4".
3. MINIMUM 1/2" DEPTH HILTI FS-ONE INTUMESCENT FIRESTOP SEALANT IS REQUIRED ON BOTH SIDES OF A WALL.

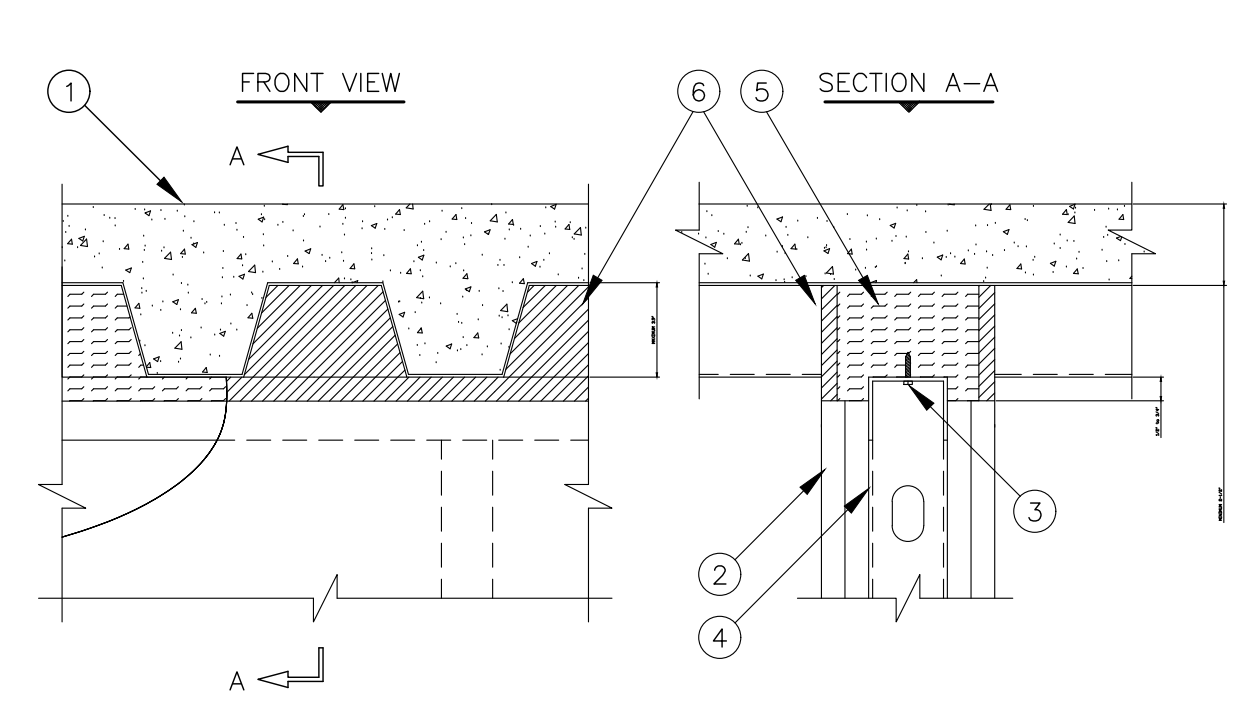


- LIGHTWEIGHT OR NORMAL WEIGHT CONCRETE FLOOR (MIN. 2-1/2" THICK) OVER METAL DECKING (1-HR. OR 2-HR. FIRE-RATING).
- GYPSUM WALL ASSEMBLY (UL/ULC CLASSIFIED U400 SERIES WALL) (1-HR. OR 2-HR. FIRE-RATING).
- CEILING RUNNER (MIN. 25 GA., WITH 2" FLANGES) FASTENED TO UNDERSIDE OF THE DECK. (SEE NOTE BELOW).
- STEEL STUDS (MIN. 2-1/2" WIDE), CUT 1/2" TO 3/4" LESS IN LENGTH THAN ASSEMBLY HEIGHT, NESTING IN CEILING RUNNER WITHOUT ATTACHMENT.
- MINIMUM 2-3/4" OR 4" THICKNESS MINERAL WOOL (MIN. 4 PCF DENSITY), FOR 1-HR. OR 2-HR. FIRE-RATED WALLS RESPECTIVELY, TO BE TIGHTLY PACKED INTO FLUTES/JOINT AND RECESSED 1/2" ON EACH SIDE OF WALL TO ACCOMMODATE SEALANT.
- MINIMUM 1/2" DEPTH HILTI CP 606 FLEXIBLE FIRESTOP SEALANT ON BOTH SIDES OF A WALL ASSEMBLY.

NOTE: AS AN ALTERNATE TO CEILING RUNNER IN ITEM NO. 3, SLOTTED CEILING RUNNER, MANUFACTURED BY SLIPTRACK SYSTEMS, INC., OR VERTIRACK, MANUFACTURED BY THE STEEL NETWORK, INC., MAY BE USED. WHEN ALTERNATE CEILING TRACKS ARE USED, CONSULT THE UL FIRE RESISTANCE DIRECTORY FOR INSTALLATION INSTRUCTIONS.

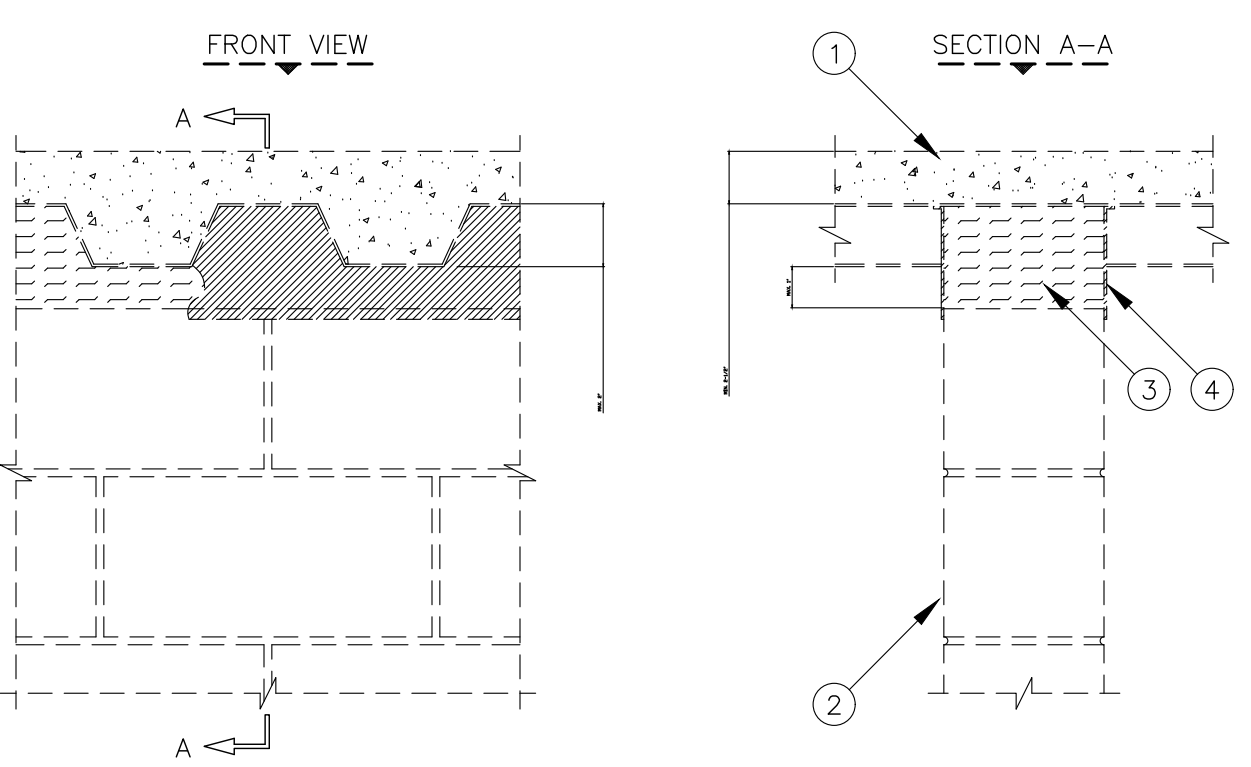


- LIGHTWEIGHT OR NORMAL WEIGHT CONCRETE FLOOR (MIN. 2-1/2" THICK) OVER METAL DECKING (2-HR. FIRE-RATING).
- CONCRETE WALL ASSEMBLY (2-HR. FIRE-RATING) :
 - LIGHTWEIGHT OR NORMAL WEIGHT CONCRETE WALL (MINIMUM 6" THICK).
 - ANY UL/ULC CLASSIFIED CONCRETE BLOCK WALL.
- MINERAL WOOL (MIN. 4 PCF DENSITY) COMPRESSED 33 PERCENT AND INSERTED INTO FLUTES, FLUSH WITH WALL SURFACES.
- MINIMUM 1/8" (WET) THICKNESS HILTI CP 672 FIRESTOP JOINT SPRAY TO COMPLETELY COVER MINERAL WOOL AND TO OVERLAP A MINIMUM 1/2" ONTO CONCRETE WALL AND METAL DECKING ON BOTH SIDES OF WALL ASSEMBLY.

NOTES: 1. STEEL FLOOR UNITS MAY BE SPRAYED WITH A MINIMUM 5/16" THICKNESS TO MAX. 1-3/4" THICKNESS OF UL CLASSIFIED MONOKOTE TYPE MK-6/HY FIREPROOFING MANUFACTURED BY W.R. GRACE.
2. WHEN THE STEEL DECK IS COATED WITH FIREPROOFING, HILTI CP 672 SHALL OVERLAP THE WALL A MIN. OF 1/2" AND OVERLAP THE FIREPROOFING A MIN. 2" ON BOTH SIDES OF THE WALL.

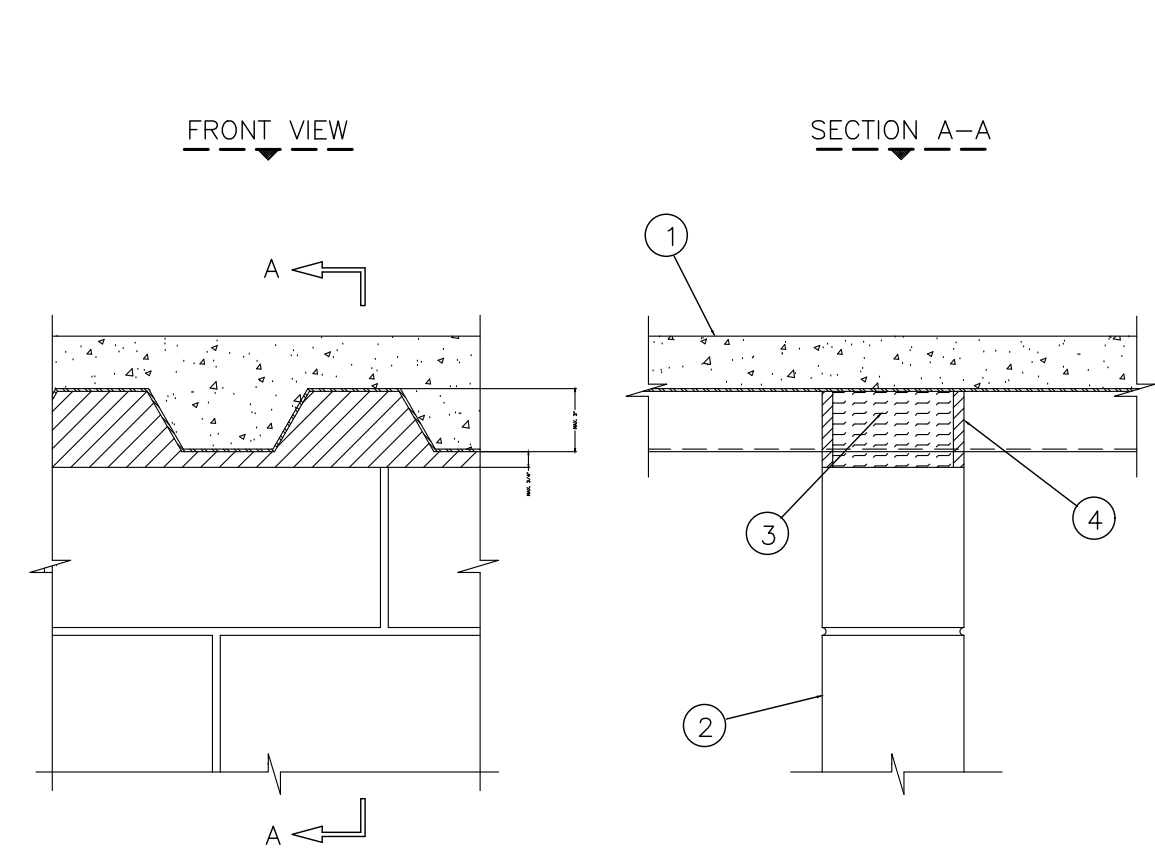

- LIGHTWEIGHT OR NORMAL WEIGHT CONCRETE FLOOR (MIN. 2-1/2" THICK) OVER METAL DECKING (2-HR. FIRE-RATING).
- CONCRETE WALL ASSEMBLY (2-HR. FIRE-RATING):
 - LIGHTWEIGHT OR NORMAL WEIGHT CONCRETE WALL (MIN. 5" THICK).
 - ANY UL/ULC CLASSIFIED CONCRETE BLOCK WALL.
- MINIMUM 4" THICKNESS MINERAL WOOL (MIN. 4 PCF DENSITY) TIGHTLY PACKED.
- MINIMUM 1/2" DEPTH HILTI CP 606 FLEXIBLE FIRESTOP SEALANT FLUSH WITH BOTH SIDES OF WALL ASSEMBLY.

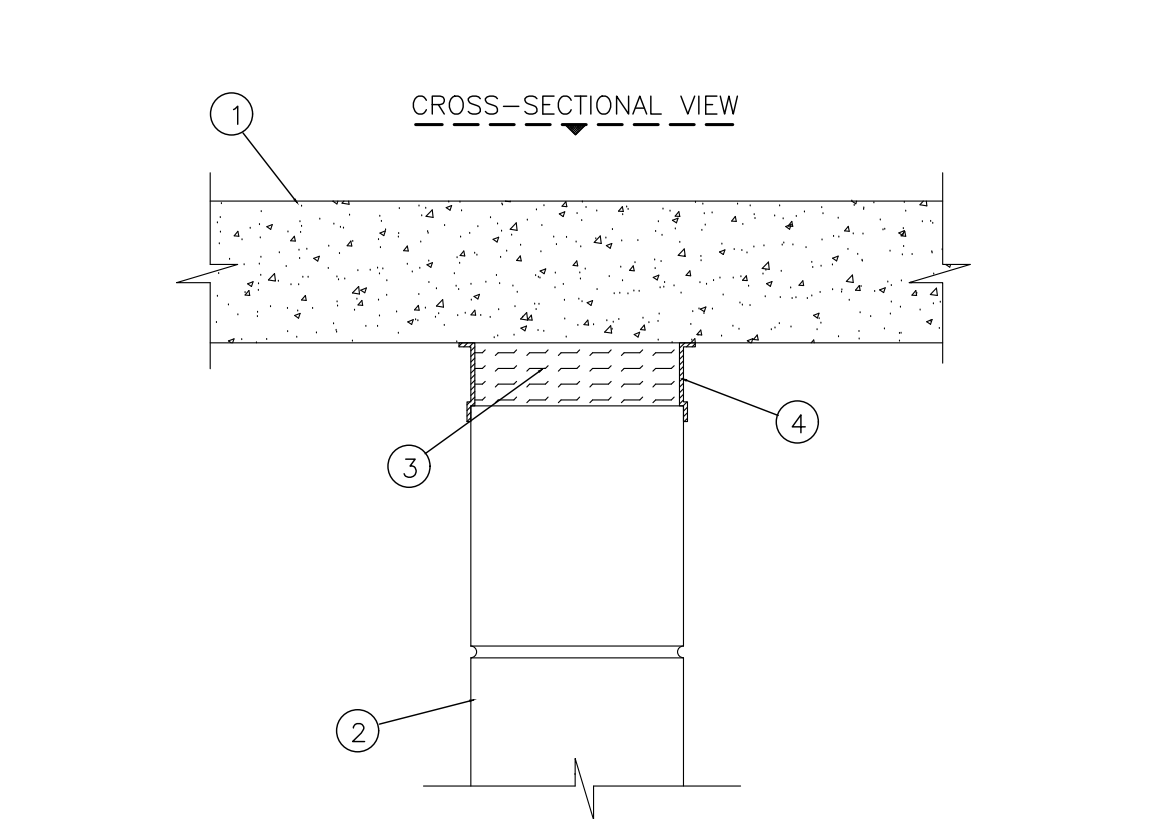


- LIGHTWEIGHT OR NORMAL WEIGHT CONCRETE FLOOR (MIN. 4-1/2" THICK)(2-HR. FIRE-RATING)
- CONCRETE WALL ASSEMBLY (2-HR. FIRE-RATING):
 - LIGHTWEIGHT OR NORMAL WEIGHT CONCRETE WALL (MIN. 4-3/8" THICK).
 - ANY UL/ULC CLASSIFIED CONCRETE BLOCK WALL.
- MINIMUM 4-3/8" THICKNESS MINERAL WOOL (MIN. 4 PCF DENSITY) COMPRESSED 50 PERCENT.
- MINIMUM 1/8" (WET) THICKNESS HILTI CP 672 FIRESTOP SPRAY APPLIED WITHIN THE JOINT, FLUSH WITH EACH SURFACE OF WALL AND LAPPING A MINIMUM 1/2" ONTO FLOOR AND WALL ON BOTH SIDES OF JOINT.

NOTE : MAXIMUM WIDTH OF JOINT = 2".

Notes:

- Refer to the specifications. For Quality Control requirements, refer to the Quality Control portion of the specification.
- Details shown are typical details. If field conditions do not match requirements of typical details, approved alternate details shall be utilized. Field conditions and dimensions need to be verified for compliance with the details, including but not limited to the following:
 - Minimum and maximum Width of Joints
 - Type and thickness of fire-rated construction. The minimum assembly rating of the firestop assembly shall meet or exceed the highest rating of the adjacent construction.
- If alternate details matching the field conditions are not available, manufacturer's engineering judgment drawings are acceptable. Drawings shall follow the International Firestop Council (IFC) Guidelines for Evaluating Firestop Systems Engineering Judgments.
- References:
 - 2001 Underwriter's Laboratories Fire Resistance Directory, Volumes 1 & 2
 - NFPA 101 Life Safety Code
 - 2001 Directory of Listed Materials and assemblies, Omega Paint Laboratories
 - NFPA 70 - National Electric Code
 - All governing local and regional building codes
- Firestop System installation must meet requirements of ASTM E-814 (UL 1479) tested assemblies that provide a fire rating equal to that of construction being penetrated.
- All rated through-penetration assemblies shall be prominently labeled with the following information:
 - ATTENTION: Fire Rated Assembly
 - UL System #
 - Product(s) used
 - Hourly Rating (F-Rating)
 - Installation Date
- For outlet boxes requiring protection, use only Wall Opening Protective Materials, category CLV as classified by Underwriter's Laboratories, Fire Resistance Directory (Volume 1.)

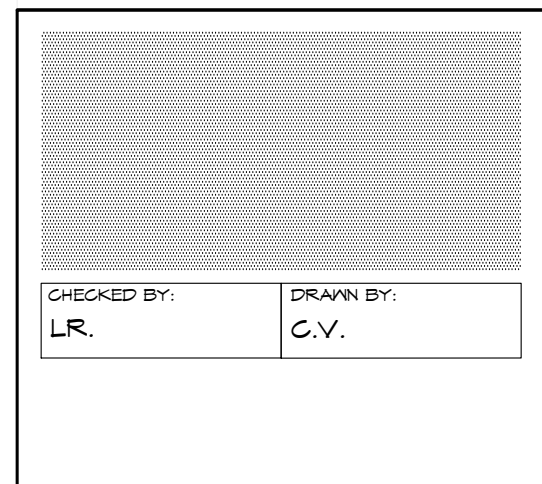


CONSULTANT INFO:




NEW ELEMENTARY SCHOOL (K-5)
VENETIAN PARC WEST
SOUTHWEST 157th AVENUE and 174th STREET
MIAMI, FL. 33187
MDCPS PROJECT No. 01892600


KEY PLAN

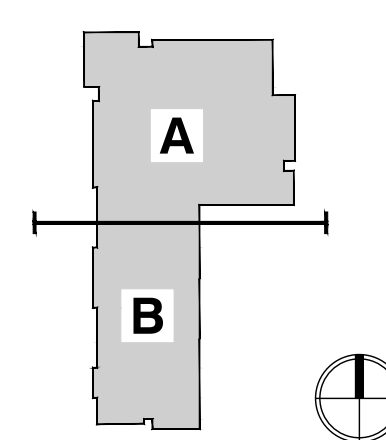

CONSULTANT INFO:

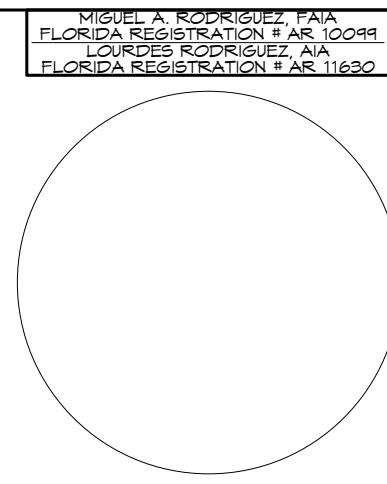

RODRIGUEZ ARCHITECTS INCORPORATED
2121 PONCE DE LEON BLVD. STE. 1010
CORAL GABLES, FL. 33134
TEL: (305) 448-3373
FAX: (305) 448-3374
A A C - 0 0 1 9 3 3

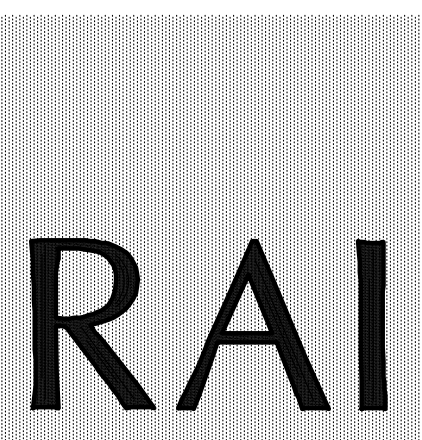

REVISIONS:



NO.	DESCRIPTION

DRAWING TITLE:

FIRESTOP PENETRATION DETAILS	
SCALE AS NOTED	
ISSUE DATE 12/16/19	PROJECT NO. 1906
SHEET: A-662	

KEY NOTES

- (A) DOUBLE-TOILET-ROLL-DISPENSER-SHELF (NOT USED)
(B) CHANGING TABLE/KOALA BEAR KARE/KB110-SSRE
(C) 3 STATION LAVATORY (TRI-FOUNT)
(C1) 3 STATION LAVATORY (CORNER-FOUNT)
(D) TOILET TISSUE DISPENSER
(E) SOAP DISPENSER/WALL MOUNTED
(F) RECESSED HAND DRYER
(G) WALL-MOUNTED HAND DRYER (NOT USED)
(H) MIRRORS: 24" x 24" WALL MOUNTED W/ S.S. FRAME
(I) STAINLESS SHELF (NOT USED)
(J) MIRRORS: FULL HEIGHT 18"W X 60"H
(K) MIRRORS: 18" x 24" WALL-MOUNTED W/ S.S. FRAME (NOT USED)
(K1) TILT-MIRRORS: 18" x 24" WALL MOUNTED W/ S.S. FRAME
(L) MIRRORS: STUDENT/PUBLIC AREA 8'L X 2'H (NOT USED)
(L1) MIRRORS: STUDENT/PUBLIC AREA 6'L X 2'H (NOT USED)
(M) FEMININE NAPKIN DISPOSAL/PARTITION MOUNTED (TWO COMPARTMENTS) (NOT USED)
(N) FEMININE NAPKIN DISPOSAL/WALL MOUNTED
(O) FEMININE NAPKIN VENDER/WALL-MOUNTED (NOT USED)
(P) FEMININE NAPKIN VENDER/WALL MOUNTED (N.I.C.)
(Q) GRAB BAR - 36"
(R) GRAB BAR - 42"
(R1) CORNER SHOWER BAR
(S) FOLDING STL. ST. SHOWER SEAT
(T) HEAVY DUTY SHOWER CURTAIN ROD WITH CONCEALED MOUNTING
(T1) HANDHELD ADJUSTABLE SHOWER FIXTURE
(U) WATER CLOSET: FLOOR MOUNTED
(V) LAVATORY: 20" X 18" WALL HUNG
(W) URINAL: HANDICAP HEIGHT
(W1) URINAL: STANDARD HEIGHT
(X) TOWEL HOOK/BOOK BAG HOOK
(Y) SURFACE MOUNTED PAPER TOWEL DISPENSER & WASTE RECEPTACLE (SMALL)
(Z) PAPER TOWEL-DISPENSER/WALL-MOUNTED (SMALL) (NOT USED)
(AA) PAPER TOWEL/WASTE/ (RECESSED) (NOT USED)
(BB) PAPER TOWEL/WASTE/ (SURFACE MOUNTED)
(CC) ADA-FOLD-DOWN BENCH 24" X 48" FIX-TO-WALL-17" A.F.F (NOT USED)
(DD) DRINKING FOUNTAIN

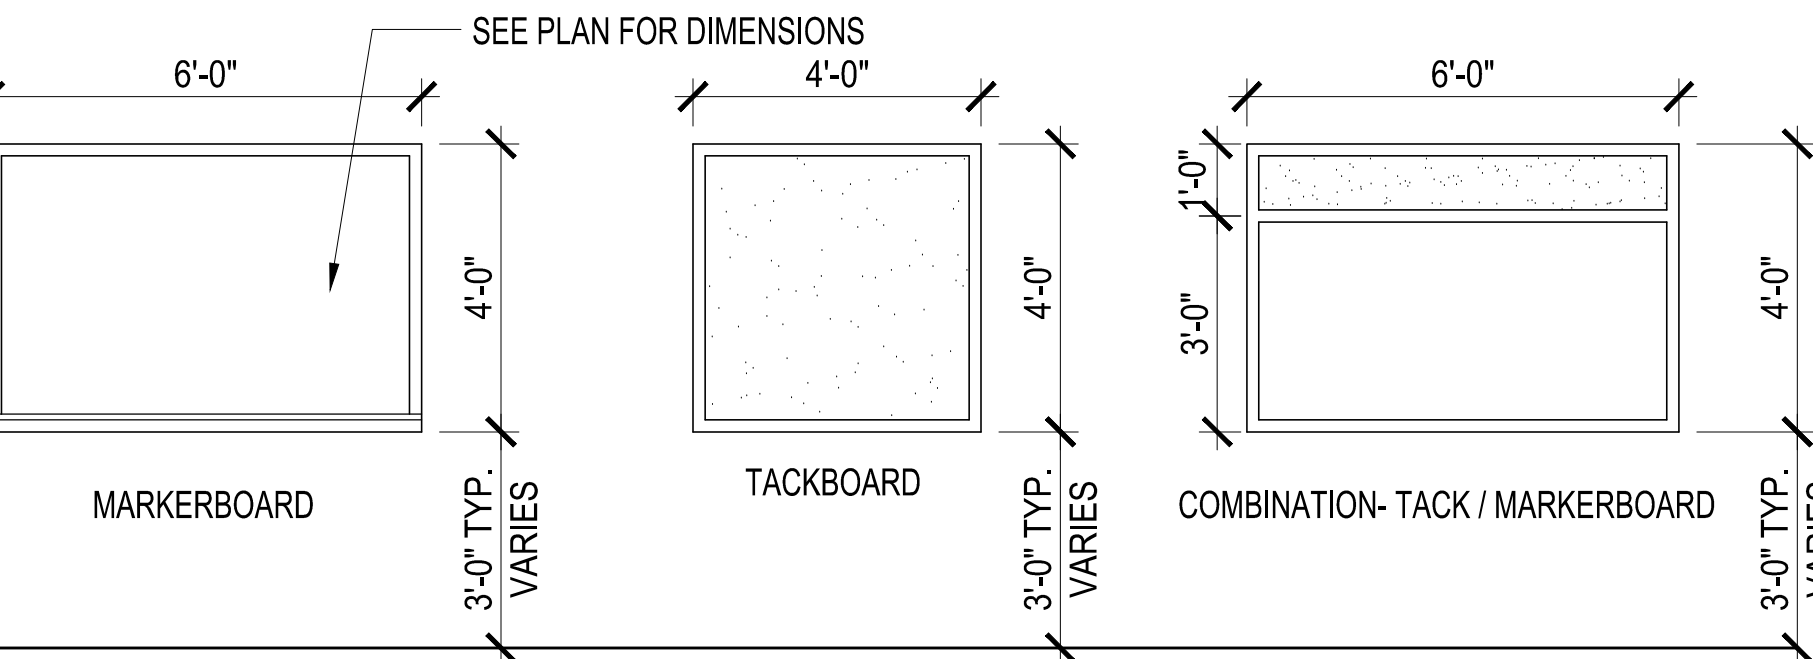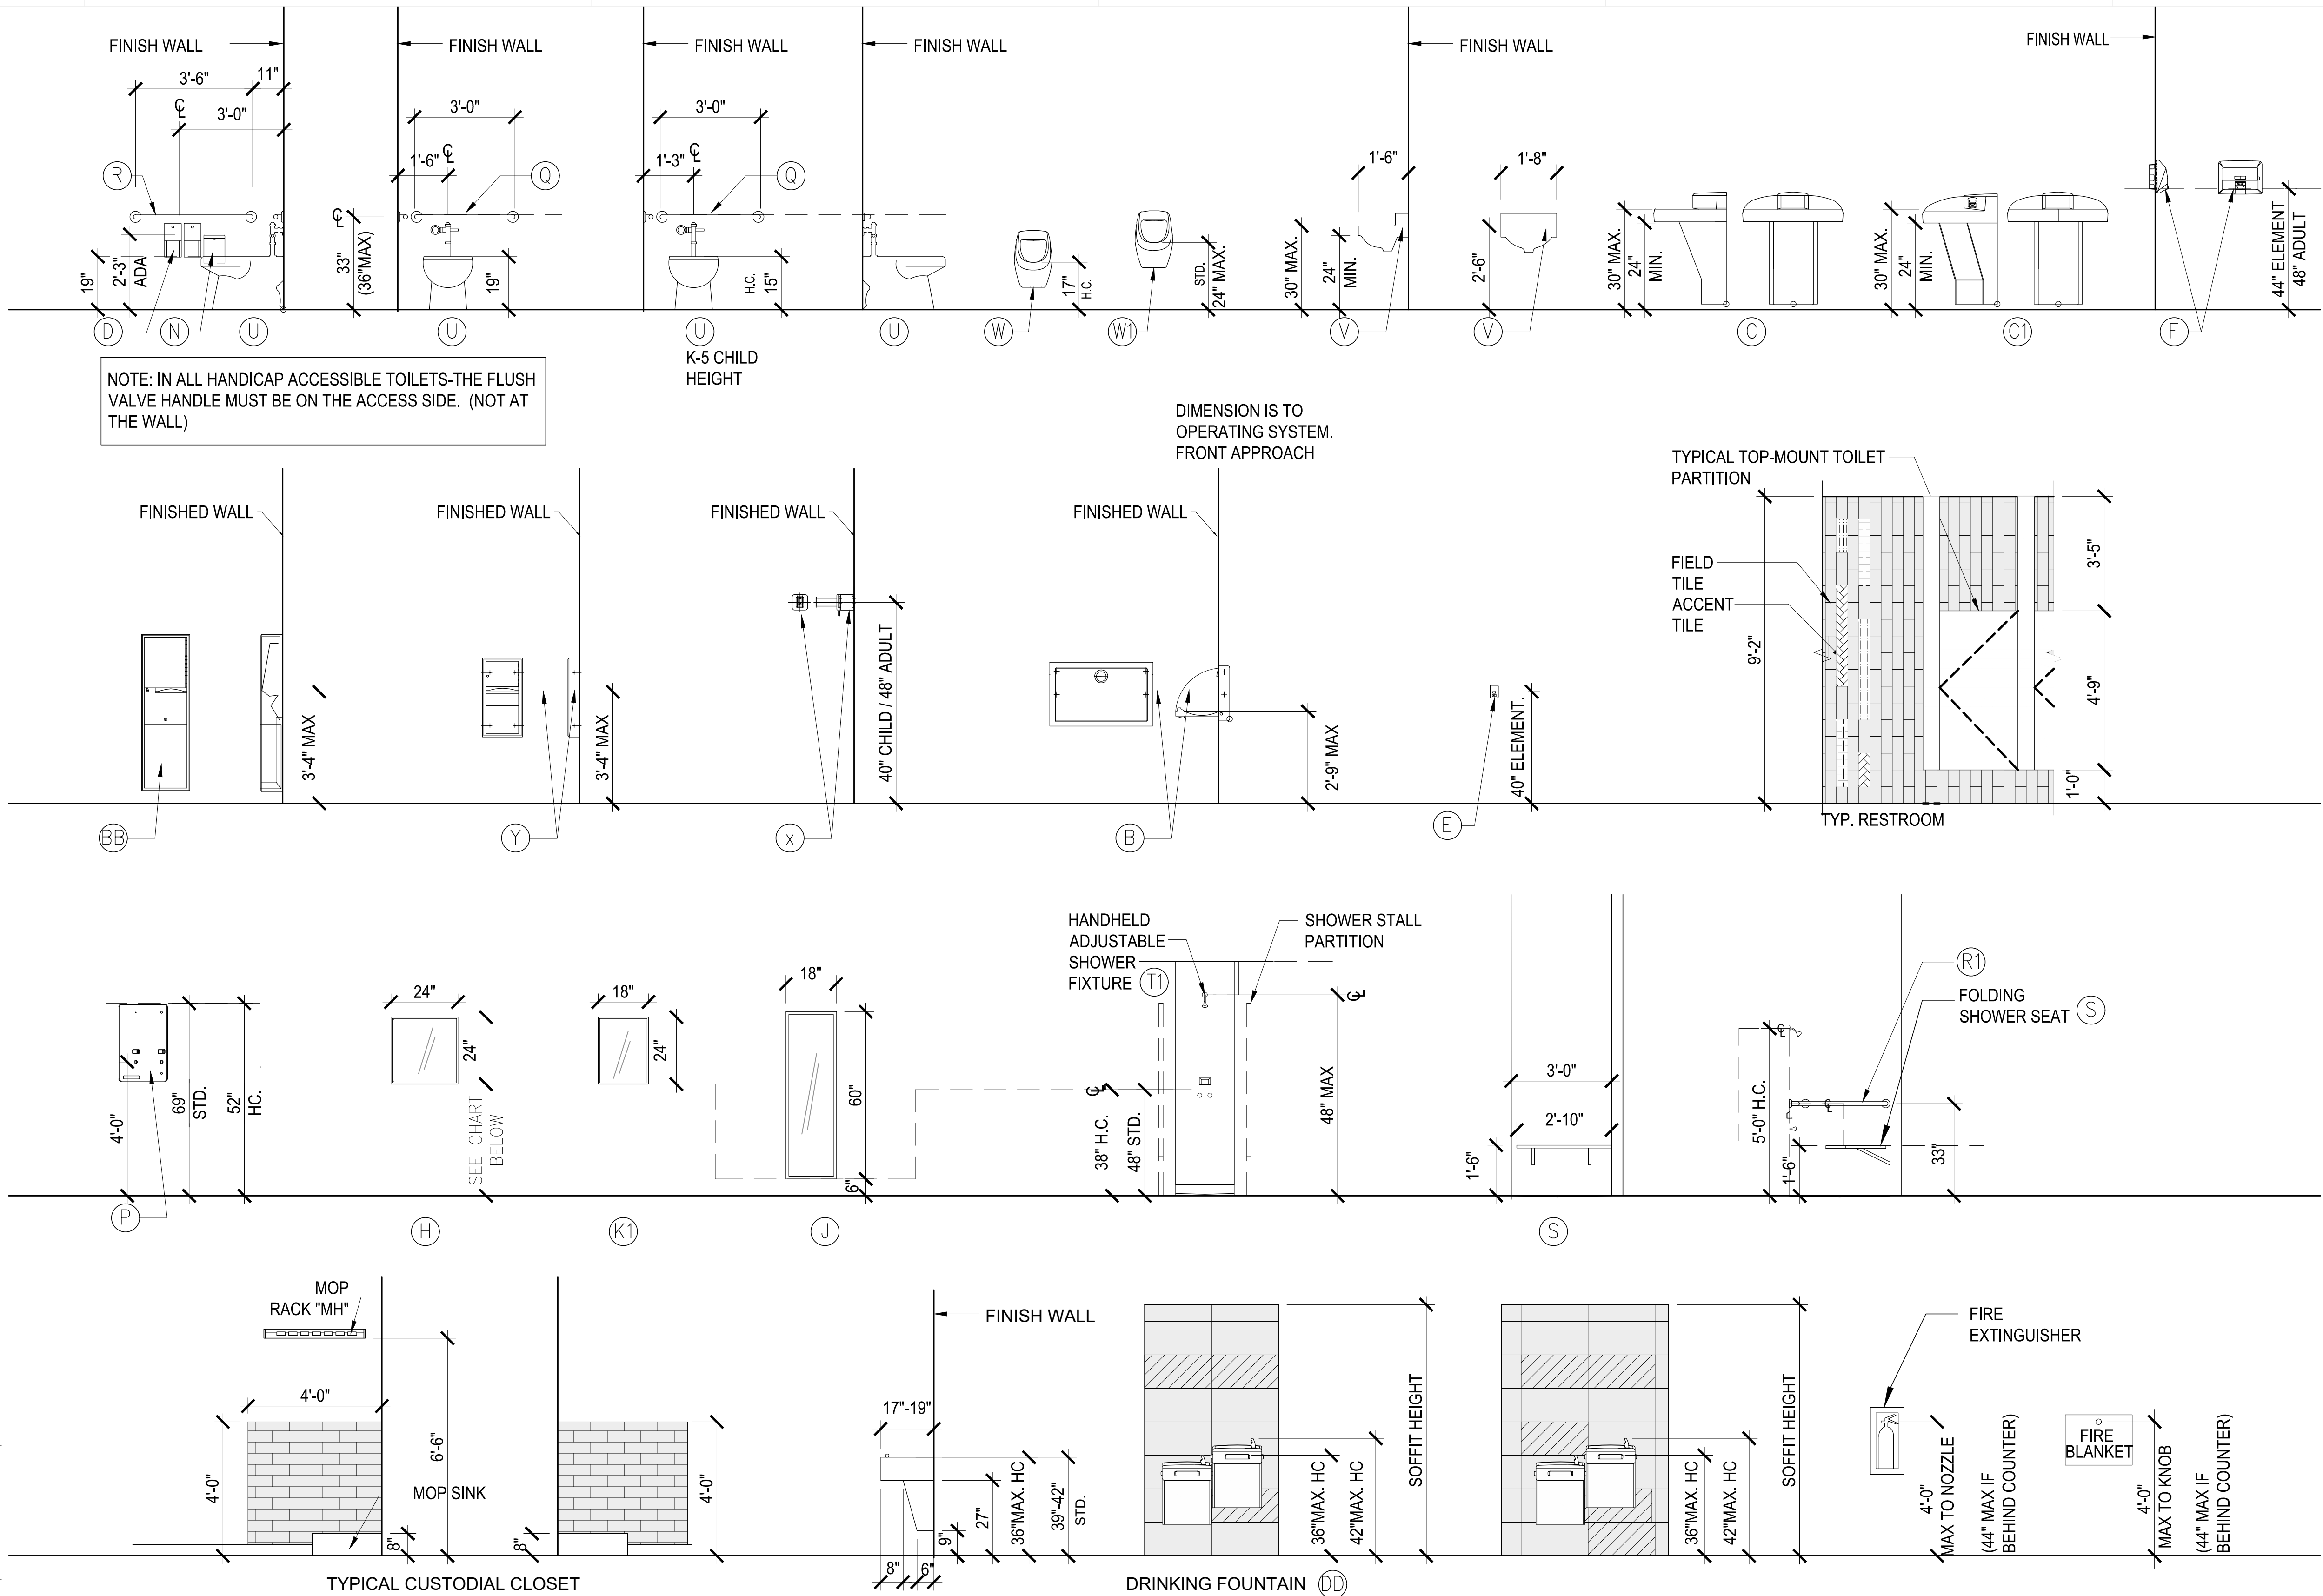


TOILET MOUNTING HEIGHTS

GENERAL NOTES

- A. TOILET TYPE A (STANDARD):
* ALL STAFF/PUBLIC TOILETS IN BUILDING
B. TOILET TYPE B (CHILDREN ACCESSIBLE)
* ALL TOILETS WITHIN CLASSROOMS AND AT CHILDREN GROUP TOILETS


	TOILET TYPE A	TOILET TYPE B
WATER CLOSET CENTERLINE	18"	15"
TOILET SEAT HEIGHT	19"	15"
GRAB BAR HEIGHT	33" (36" MAX)	25"
TOILET DISPENSER HEIGHT	12" ABOVE GRAB BAR	
T.O. LAVATORY	34" MAX.	30" MAX.
B.O. LAVATORY	27" MIN.	24" MIN.
PAPER TOWEL HEIGHT	46" SIDE/44" FRONT	40"
URINAL	15"	15"
WATER FOUNTAIN-SPOUT	36"/42"	30"/36"/42"
ELECTRICAL SWITCH	44" MAX	40" MAX
MIRRORED LOWER EDGE	40"	34"

1. PROVIDE 4 1/4" x 4 1/4" WALL TILE TO 5'-0" AFF AND 2'-0" x 2'-0" FLOOR TILE, TYPICAL @ INDIVIDUAL TOILETS
2. PROVIDE BULL NOSE TILE AT ALL TRANSITIONS FROM TILE TO DRYWALL.
3. PROVIDE COVED BASE TILE @ ALL LOCATIONS
4. NO TILE PIECES LESS THAN 1/2 TILE WILL BE PERMITTED
5. REFER TO COLOR BOARD FOR ALL FINISHES
6. REFER TO DIVISION 15, SECTION 15440 SPECIFICATIONS FOR ALL TOILET/PLUMBING FIXTURES.
7. REFER TO SPEC SECTION 102800. FOR ALL TOILET ACCESSORIES.
8. PROVIDE VANDAL RESISTANT FASTENERS AND BACKING IN PARTITION OR WALL FOR SUFFICIENT ANCHORING TO RESIST A 250# FORCE APPLIED IN ANY DIRECTION.
9. CONTRACTOR TO SUBMIT PLUMBING ROUGH-IN DRAWINGS DURING THE SUBMITTAL PROCESS FOR GRAB BAR COORDINATION.

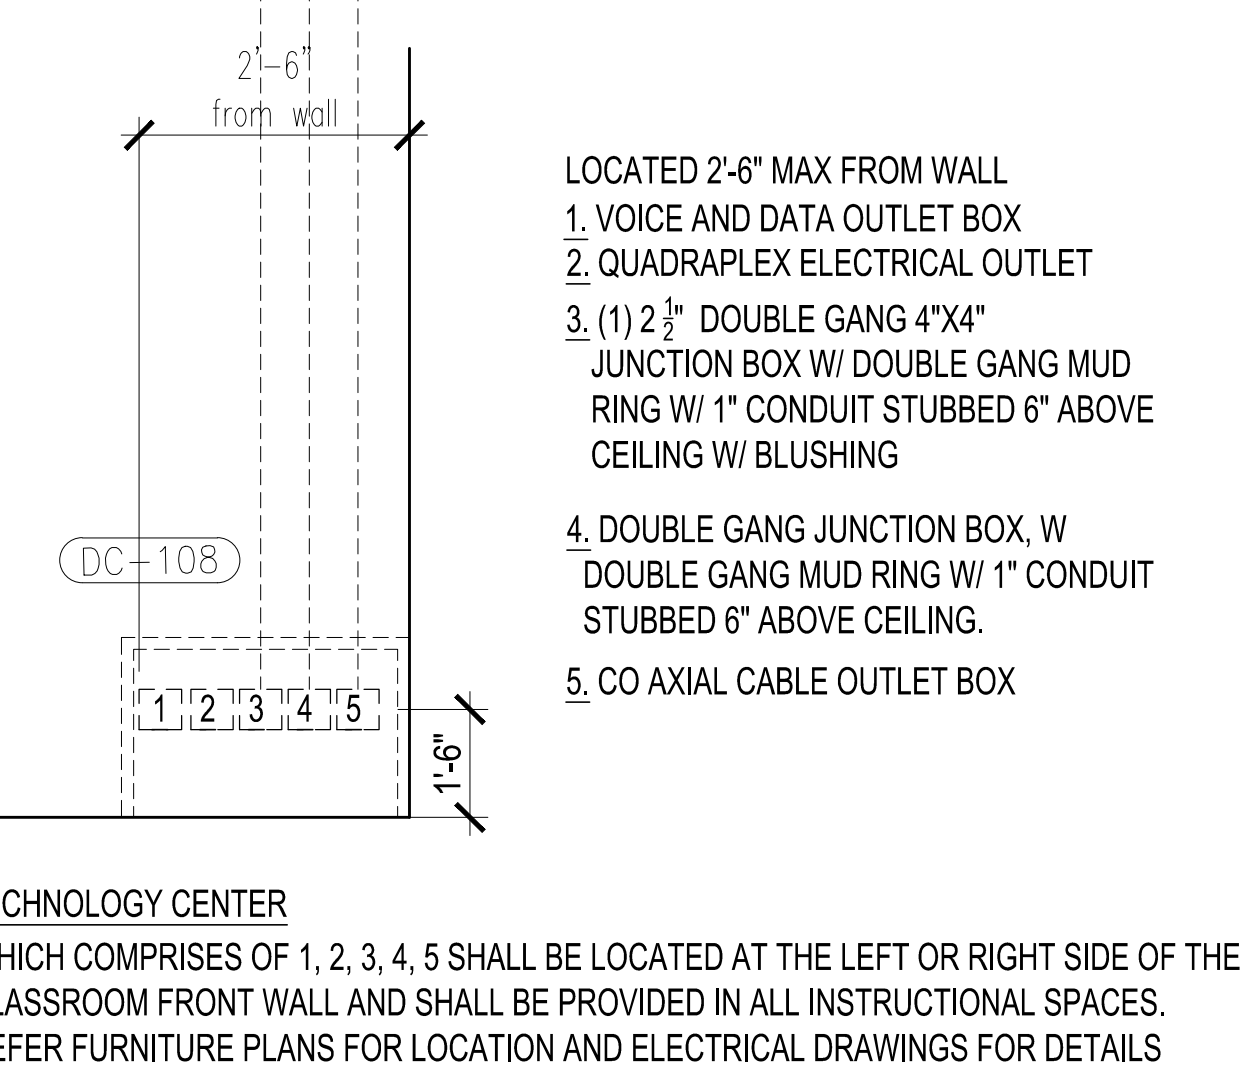

MOUNTING HEIGHTS

Scale: 3/8" = 1'-0"

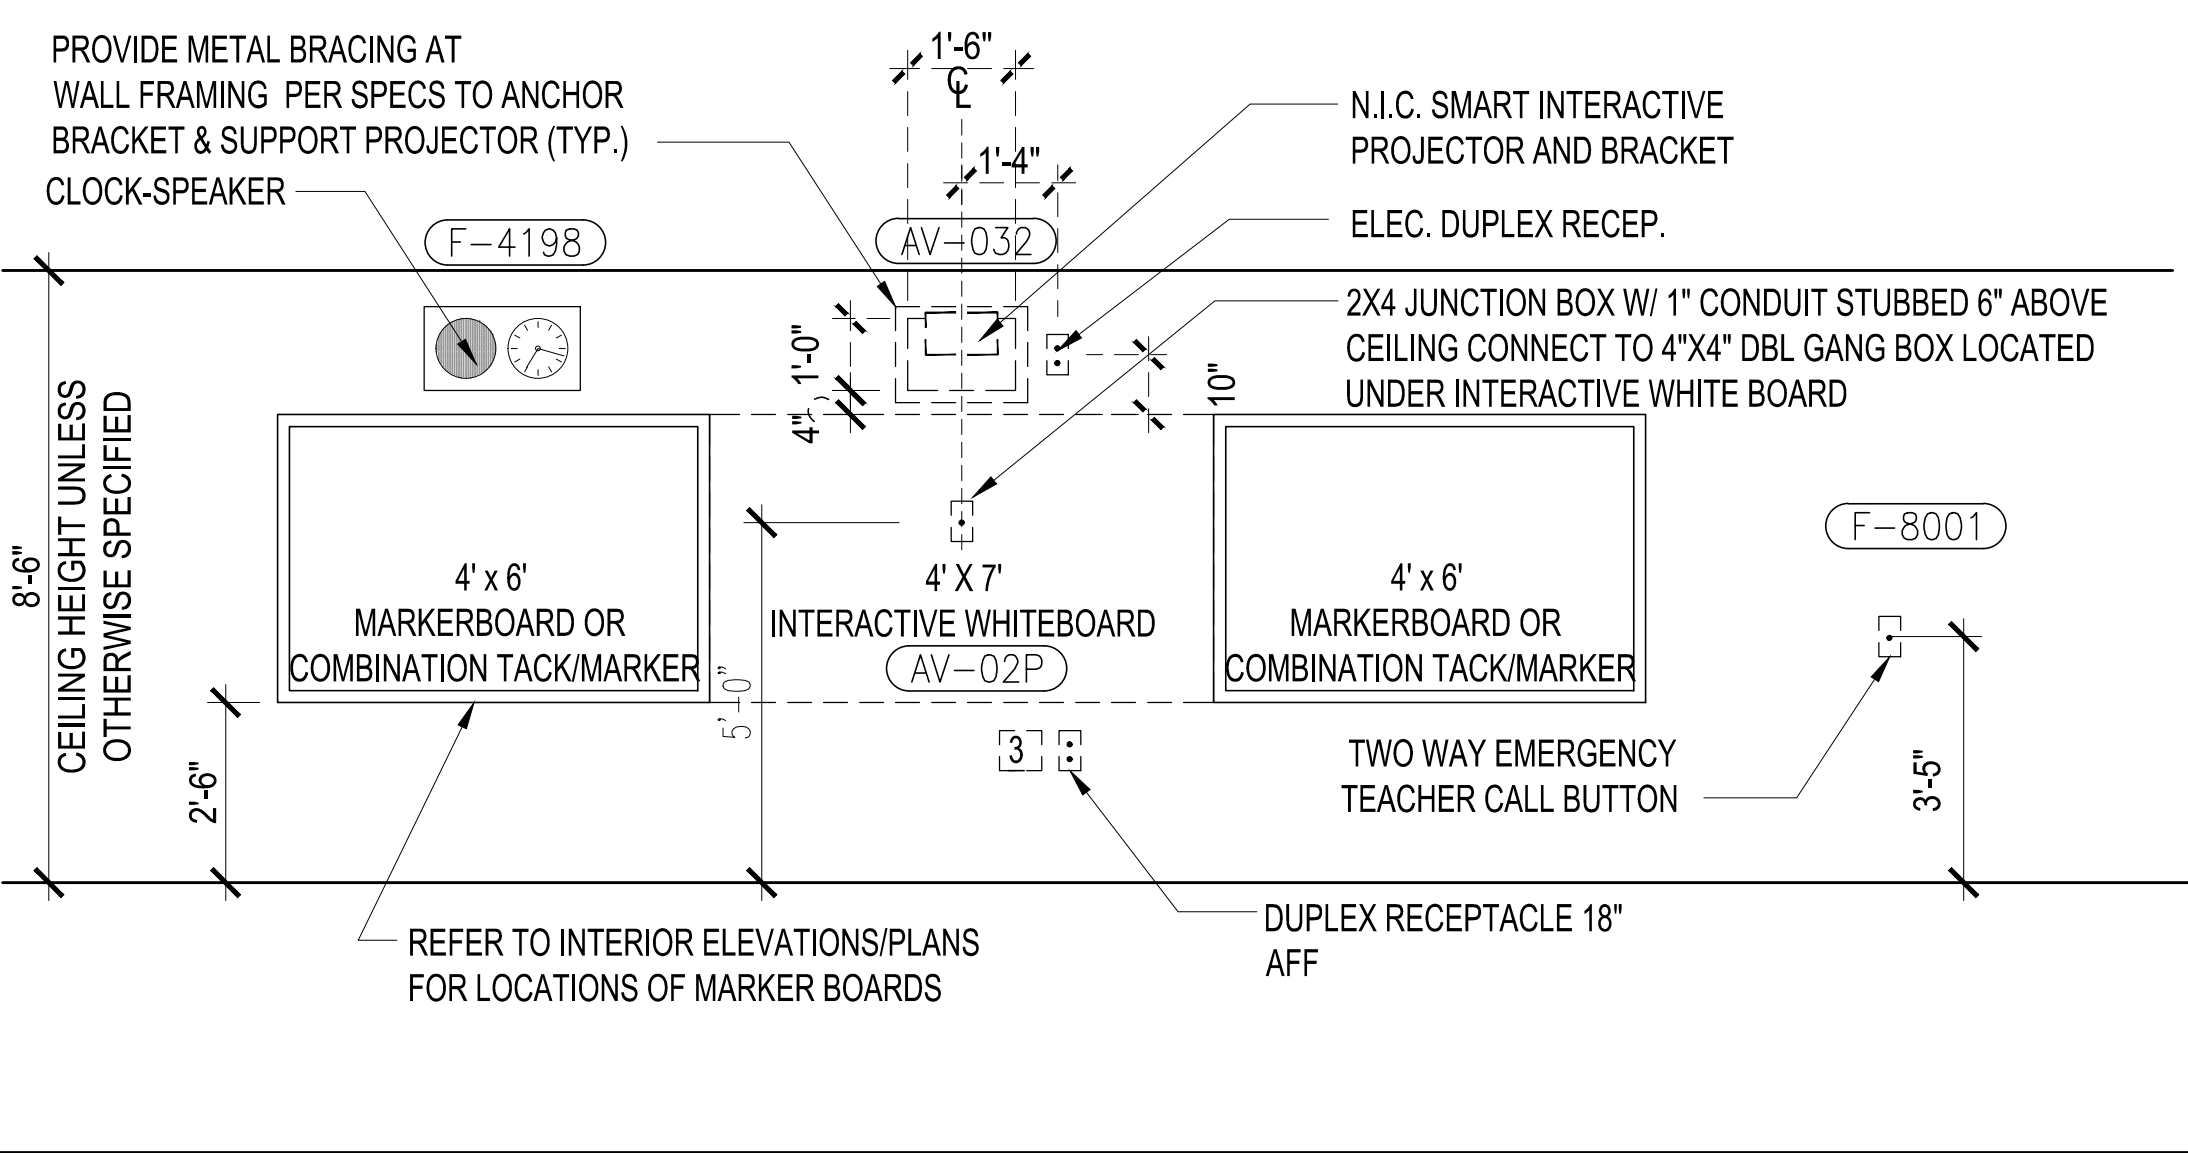

CLASSROOM TECHNOLOGY LAYOUT

NOTES: THIS SKETCH IS INTENDED TO ILLUSTRATE ONLY THOSE ELEMENTS RELATED TO THE INSTRUCTIONAL TECHNOLOGY SYSTEM. SEE M-DCPS DESIGN STANDARDS FOR ADDITIONAL REQUIREMENTS.

CHECKED BY: LR. DRAWN BY: CV.

CONSULTANT INFO:




NEW ELEMENTARY SCHOOL (K-5)


VENETIAN PARC WEST

SOUTHWEST 157th AVENUE and 174th STREET
MIAMI, FL. 33187
MDCPS PROJECT No. 01892600


KEY PLAN

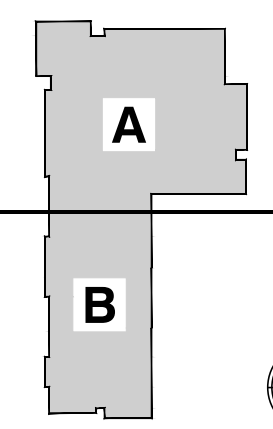

CONSULTANT INFO:

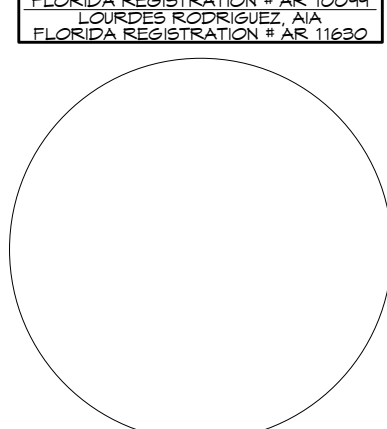

RODRIGUEZ ARCHITECTS INCORPORATED
2121 PONCE DE LEON BLVD. STE. 1010
CORAL GABLES, FL. 33134
TEL: (305) 448-3373
FAX: (305) 448-3374
A A C - 0 0 1 9 3 3


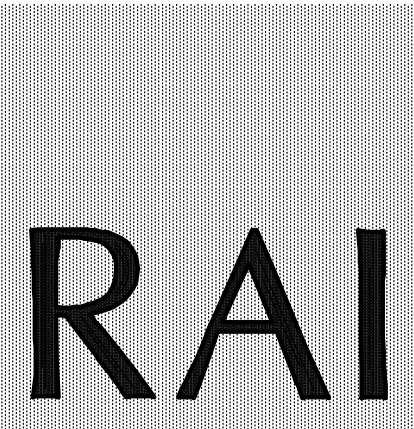


REVISIONS:



DRAWING TITLE:

TYPICAL MOUNTING HEIGHTS & NOTES

SCALE: AS NOTED
ISSUE DATE: 12/16/19
PROJECT NO: 1906
SHEET: A-700

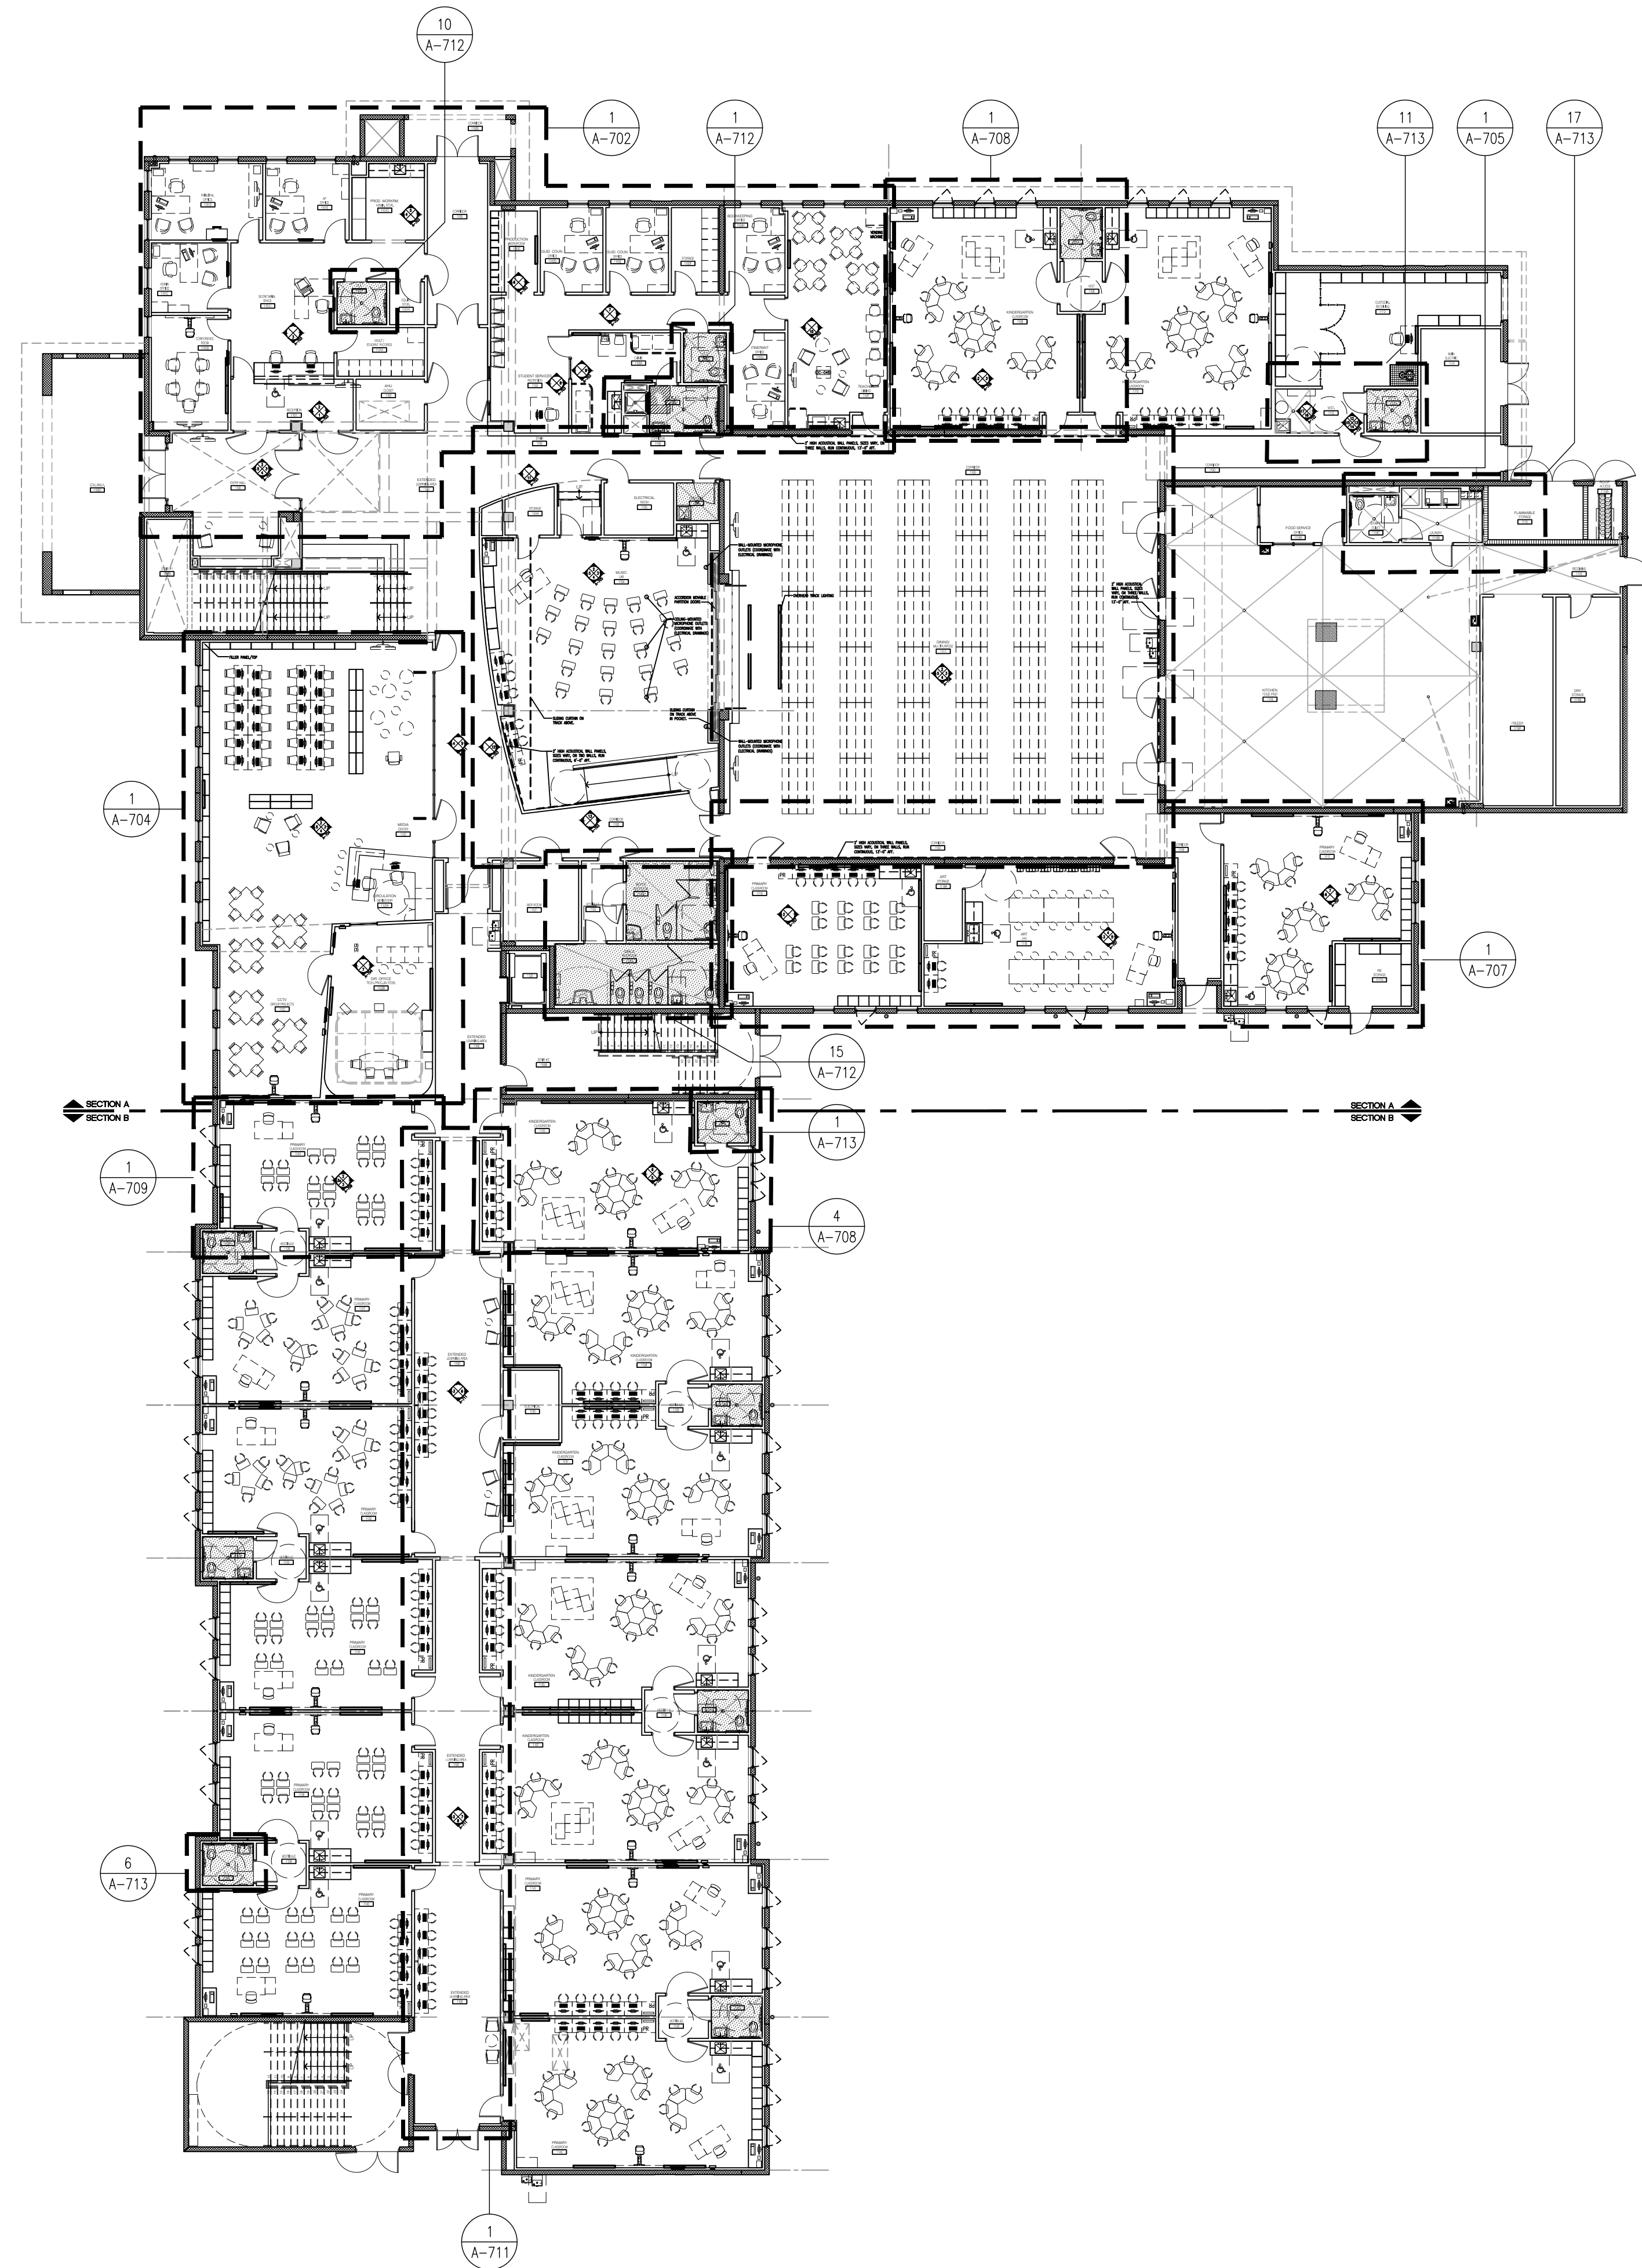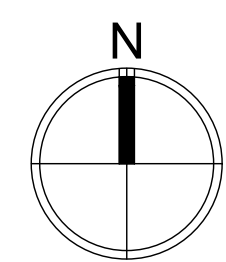


1 OVERALL FIRST FLOOR FURNITURE PLAN
A-701 Scale: 1/16" = 1'-0"

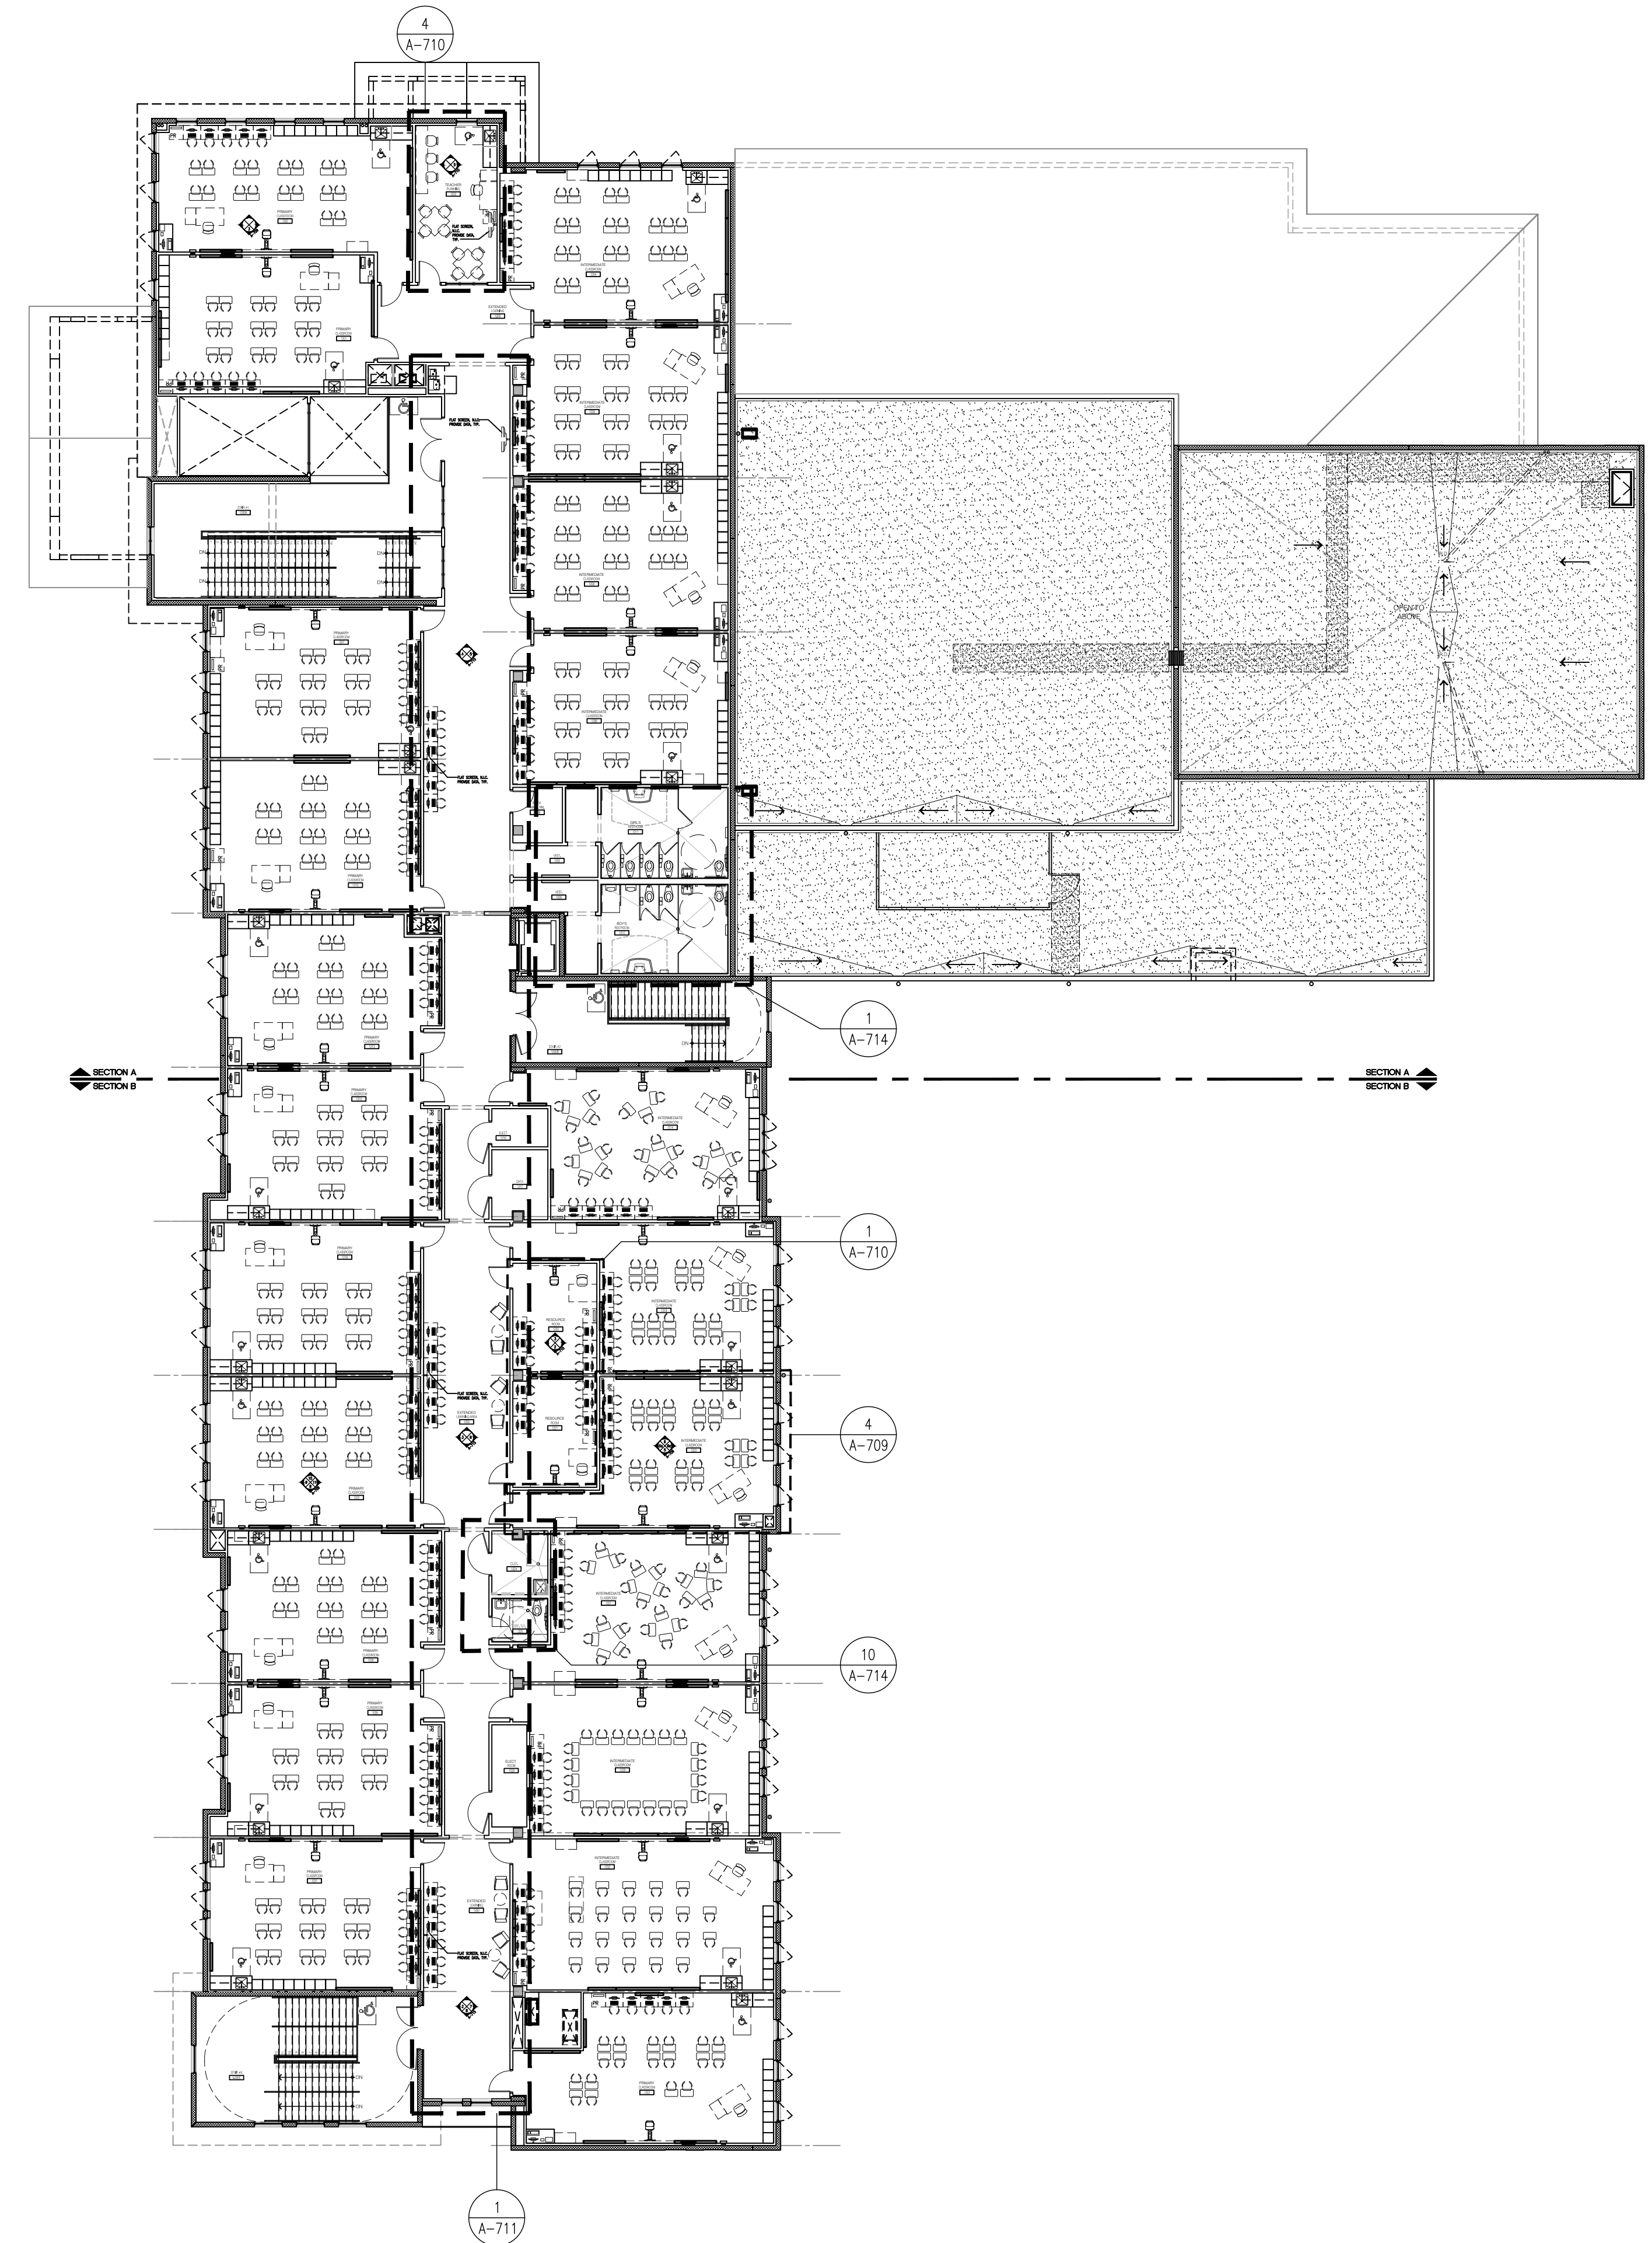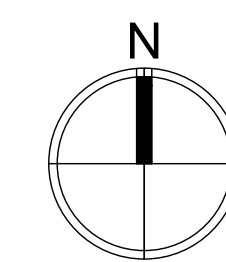

2 OVERALL SECOND FLOOR FURNITURE PLAN
A-702 Scale: 1/16" = 1'-0"


CHECKED BY: LR	DRAWN BY: CV
-------------------	-----------------

CONSULTANT INFO:

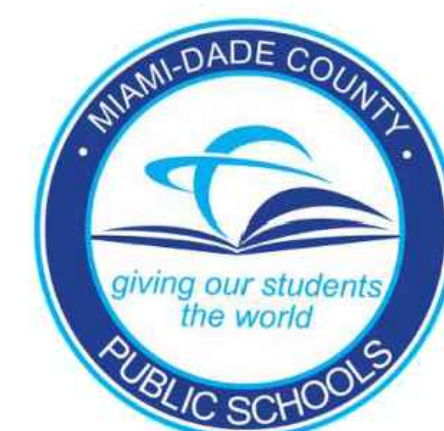

NEW ELEMENTARY SCHOOL (K-5)
VENETIAN PARC WEST
SOUTHWEST 157th AVENUE and 174th STREET
MIAMI, FL. 33187
MDCPS PROJECT No. 01892600

KEY PLAN

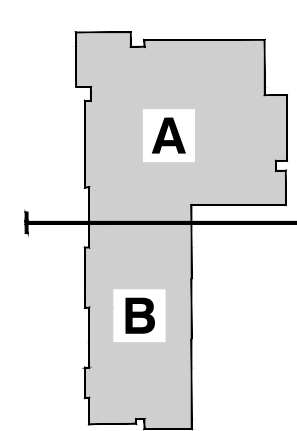

CONSULTANT INFO:

RODRIGUEZ ARCHITECTS, INC.
2121 PONCE DE LEON BLVD., STE. 1010
CORAL GABLES, FL. 33134
TEL: (305) 448-3373
FAX: (305) 448-3374


**RODRIGUEZ ARCHITECTS
INCORPORATED**
2121 PONCE DE LEON BLVD., STE. 1010
CORAL GABLES, FL. 33134
TEL: (305) 448-3373
FAX: (305) 448-3374
A A C — 0 0 1 9 3 3



REVISIONS:

NO.	DATE	DESCRIPTION

DRAWING TITLE: OVERALL FIRST & SECOND FLOOR PLAN	
SCALE: AS NOTED	PROJECT NO. 1906
ISSUE DATE 12/16/14	SHEET A-701

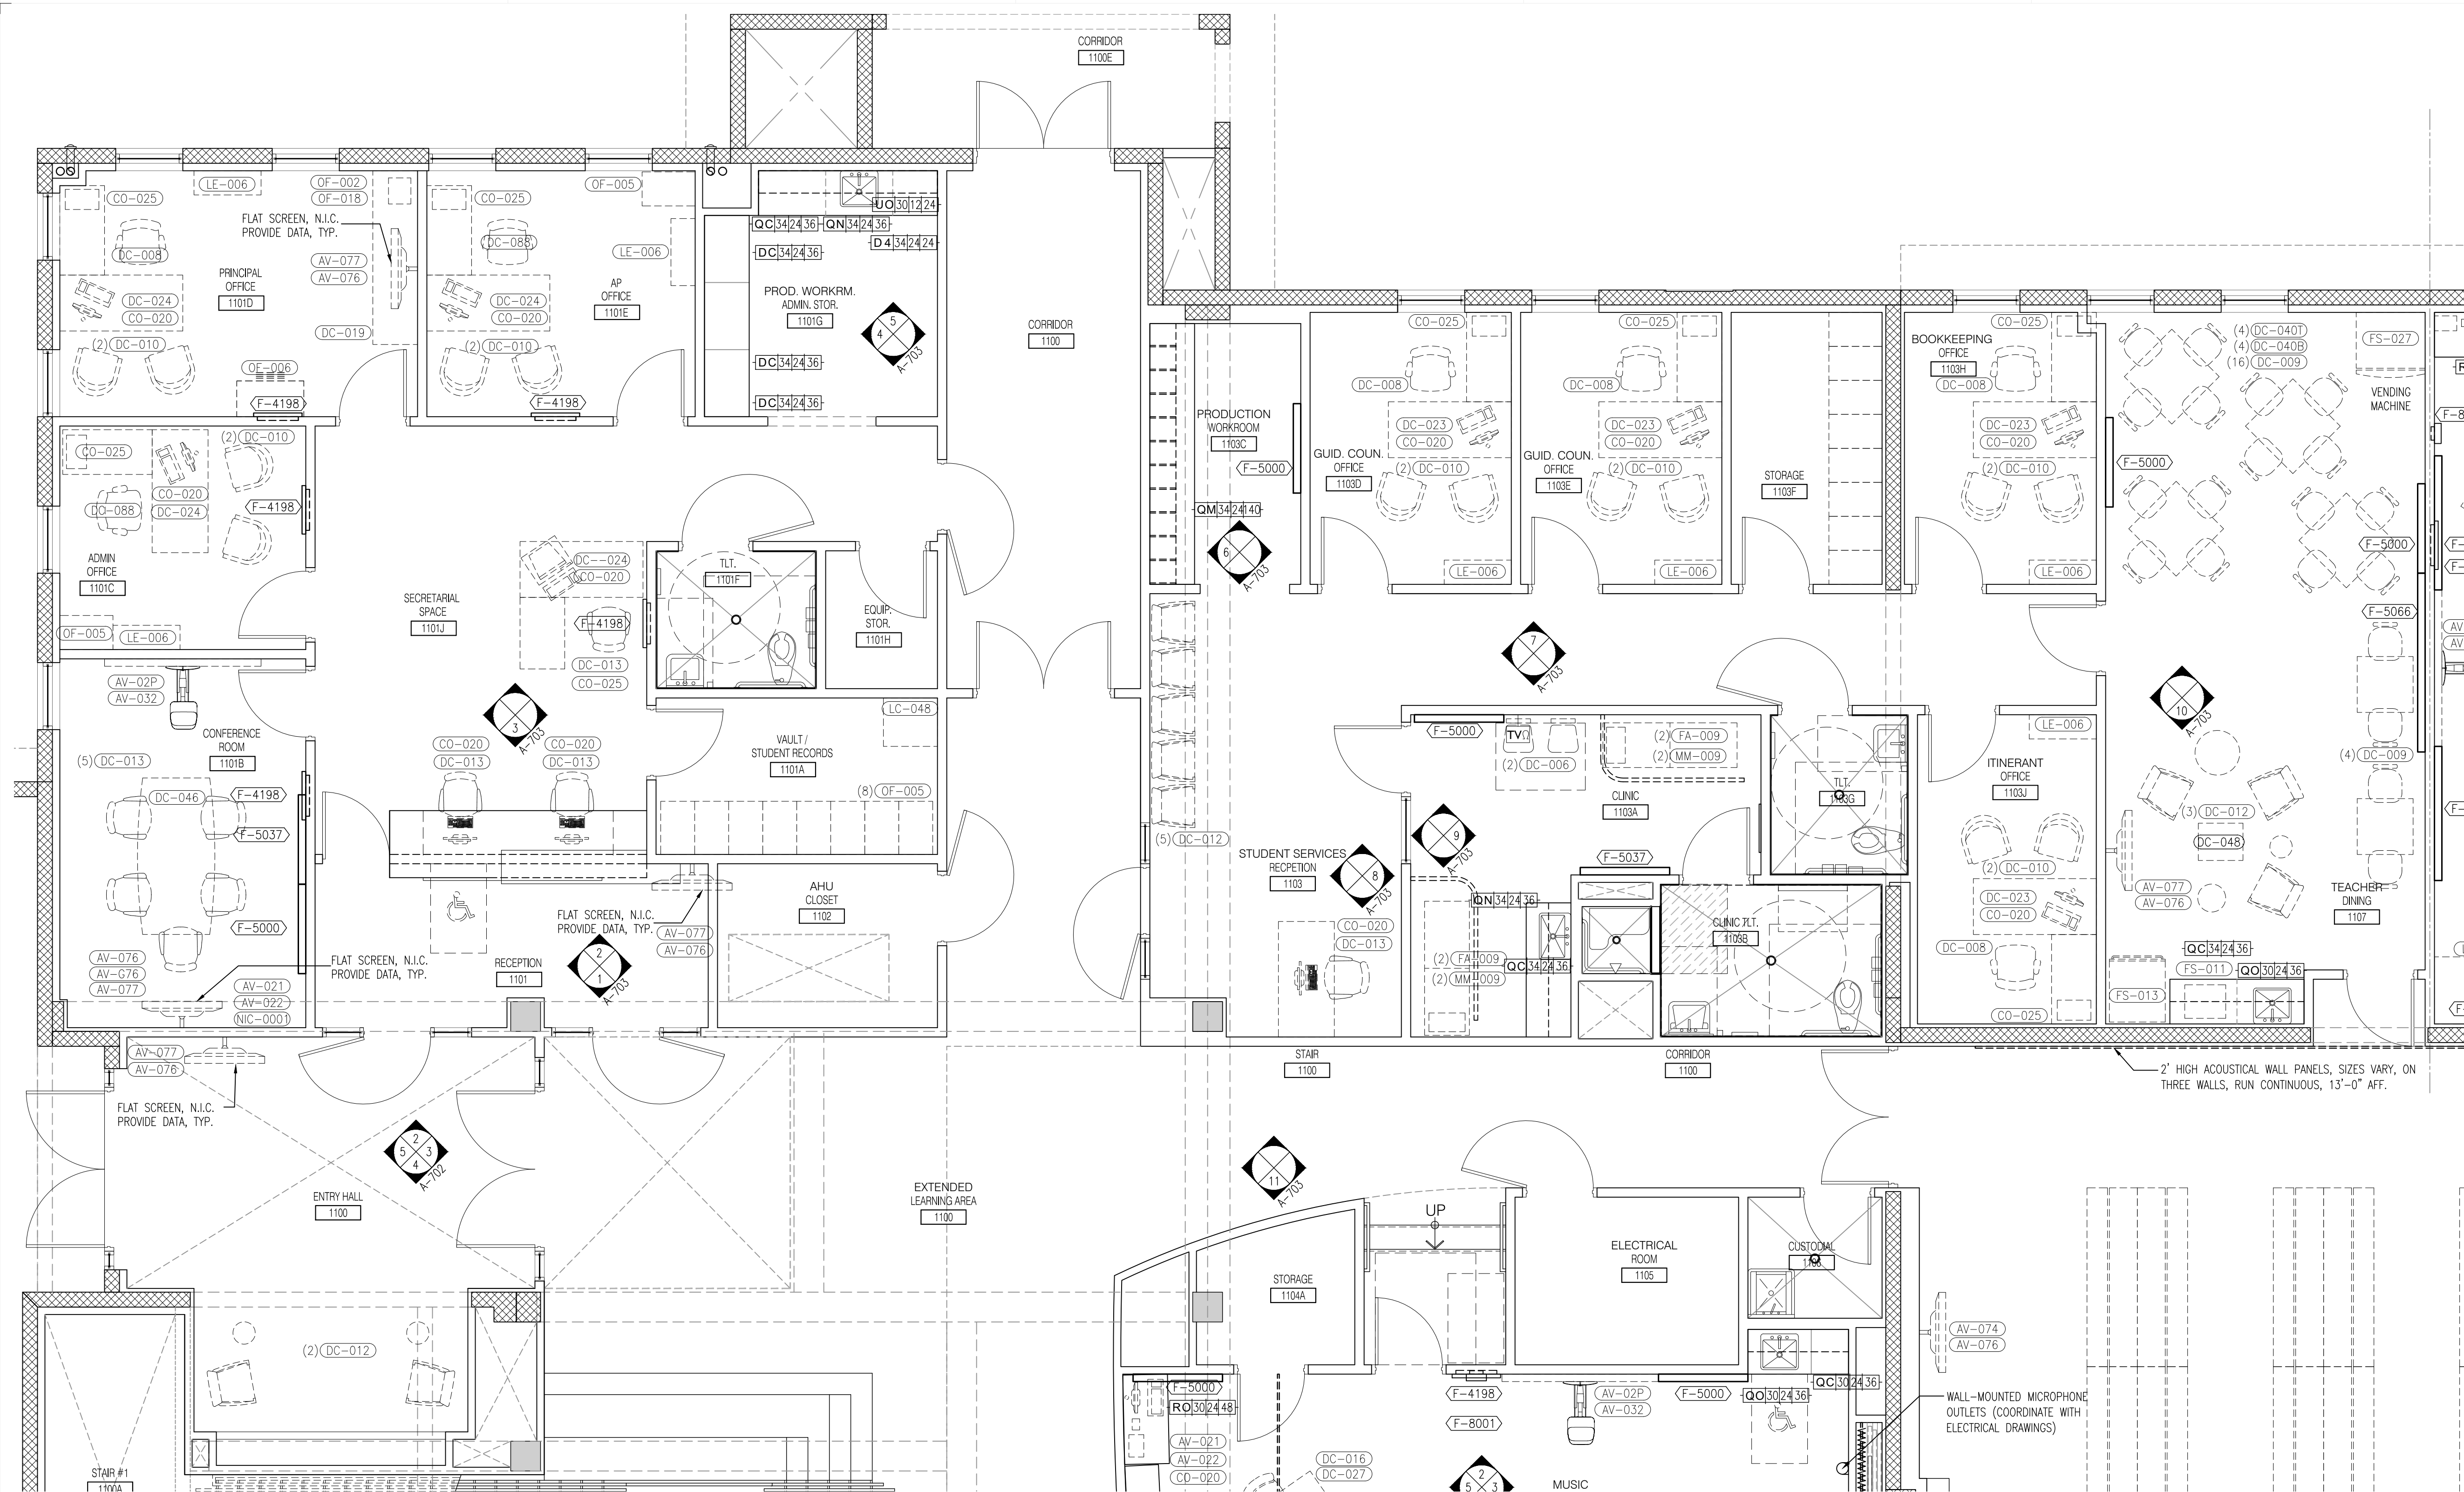

1 FIRST FLOOR ADMINISTRATION AREA - 1A
A-702 Scale: 1/4" = 1'-0"

FURNITURE, FIXTURES & EQUIPMENT SCHEDULES


IN CONTRACT ITEMS (IC)		F-XXXX				
NO.	DESCRIPTION	MANU./MODEL	SIZE	ELECT	PLUMB	GAS
F-3548	HEAVY DUTY ADJUSTABLE SHELVING		36" x 18" x 84" H			
F-4001	TV HUB		36" W X 8" D X 36" H	X		
F-4003	CEILING MOUNTED PROJECTOR BRACKET			X		
F-4008	FIRE SAFETY BLANKET	LARSEN NO. FB 68-6 SERIES	68" H X 8-1/4" W X 4" D			
F-4011	LIBRARY SHELVING		36" W X 12" D X 42" H			
F-4012	LIBRARY SHELVING		36" W X 12" D X 30" H			
F-4013	LIBRARY SHELVING		36" W X 12" D X 60" H			
F-4014	ADJUSTABLE LIBRARY SHELVING		36" W X 18" D X 84" H			
F-4200	TV HUB		36" W X 8" D X 36" H	X		
F-4035	MOTORIZED PROJECTOR SCREEN			X		
F-4036	OVERHEAD TRACK LIGHTING			X		
F-4198	CLOCK SPEAKER			X		
F-5000	TACKBOARD	CLARIDGE OR EQUAL	4'-0" x 4'-0"			W/MARKER TRAY AND MAP RAIL
F-5035	COMBINATION TACKBOARD/MARKERBOARD	CLARIDGE OR EQUAL	6'-0" x 4'-0"			
F-5037	MARKERBOARD	CLARIDGE OR EQUAL	4'-0" x 4'-0"			
F-5066	COMBINATION TACKBOARD/MARKERBOARD	CLARIDGE OR EQUAL	8'-0" x 4'-0"			
F-8001	TEACHER CALL BOX			X		
F-9000	BOOK DETECTION SYSTEM	CHECKPOINT	SEE MANUFACTURER SPEC.	X		MODEL: LIBERTY PX_MEDIA AREA

NOT IN CONTRACT ITEMS (NIC)		XX-XXX				
NO.	DESCRIPTION	MANU./MODEL	SIZE	ELECT	PLUMB	GAS
AV-676	TELEVISION AND BRACKET INSTALLATION	TROKELL INSTALLER		X		
AV-017	PROJECTION TABLE CART		24" x 18" x 34" H			
AV-029	ACTIVBOARD TOUCH	PROMETHEAN / ARMTSTBRUST	21" x 41" H	X		
AV-021	CLASSROOM SOUND SYSTEM	ACHEVER M04E-20WPA	T.B.D.	X		
AV-022	CLASSROOM EXTERNAL TUNER/ADAPTER	ACHEVER M04E-20WPA	T.B.D.	X		
AV-032	PROJECTION SYSTEM	NEC / M311X	T.B.D.	X		
AV-074	TV UNIVERSAL WALL MOUNT	TOCHIRE / S041350U	T.B.D.	X		
AV-076	TV UNIVERSAL WALL MOUNT	PEERLESS/SAT40P AND/OR STE65	T.B.D.	X		
AV-077	TELEVISION 32" FLAT PANEL	SAMSUNG / M032C	T.B.D.	X		
AV-080	MIC BOX			X		
AV-081	CAMERA			X		
AV-082	PROMPTER			X		
AV-083	CONSOLE (3 STATIONS)			X		
AV-084	TV RACK			X		
CO-020	COMPUTER, MAINSTREAM WITH MONITOR	T.B.D.		X		
CO-025	LASER PRINTER, BASIC NETWORK DUXLING	HP / P2055DN 070-L104	T.B.D.	X		
DC-004	CHAIR, DISCOVERY SERIES ERGONOMIC	ARTCO-BELL / D10A	18"			SEAT AND LEG T.B.D.
DC-006	CHAIR, DISCOVERY SERIES ERGONOMIC	ARTCO-BELL / D10A	18"			SEAT AND LEG T.B.D.
DC-008	CHAIR, EXECUTIVE HIGH BACK	HON - 2077BK	T.B.D.			
DC-009	CHAIR - PADDED SEAT	HON - H101	T.B.D.			
DC-010	GUEST CHAIR	HON - 2304N	T.B.D.			
DC-012	LOUNGE CHAIR					
DC-013	BACK CHAIR, PNEUMATIC-BACK HEIGHT SWIVEL	HON - H7701.S	T.B.D.			
DC-016	TEACHER'S SWIVEL CHAIR	SCHOLARCRAFT / SC110P	T.B.D.			
DC-019	CRENDENZA					
DC-023	DESK - EXECUTIVE	T.B.D.	72" W X 24" D X 29-1/2" H			
DC-024	DESK L-SHAPE	HON OR EQUAL 105 SERIES	72" W X 24" D X 29-1/2" H			
DC-026	STUDENT DESK		66" W X 30" D X 29" H			
DC-026	DESK, PUPIL OPEN FRONT	VIROCO / 785MBB-MPL385	18" W X 24" W / ADJ 22"-30" H			BLACK, FUSION, MAPLE TOP
DC-027	DESK, TEACHERS, SINGLE PEDESTAL	HON-H88251	48" W X 30" D			TAN METAL W/OAK LAMINATE TOP
DC-0408	TABLE-X BASE	HON - H8836.P	36" W X 36" D			
DC-0401	TABLE-SQUARE TOP	HON - H10350	36" W X 36" D			
DC-042	TABLE-ART & PLANNING	SHAIN/SHOP-BLT #1300743705	60" W X 42" D X 36" H			
DC-043	TABLE-CLASSROOM	VIROCO - 483060	30" W X 60" D X ADJ HEIGHT			BIRCH/MAPLE TOP
DC-046	TABLE - CONFERENCE	HON/CORAL - HTL4284	84" x 42" W36" W AT END5x 29" H			BIRCH/MAPLE TOP
DC-048	TABLE - END	HON - H80193	24" x 20" W 20" H			BIRCH/MAPLE TOP
DC-054	TABLE - STUDENT	VIROCO				
DC-060	TABLE/BENCH - CONVERTIBLE	MIDWEST / T88-PT 012-KK01				DINING/MULTIPURPOSE
DC-0615	STOOL, TASK, ADJUSTABLE HGT	JC WHITE/HON H7705				
DC-078	WOOD STOOL	PRIDE #30				
DC-088	CHAIR EXECUTIVE MID BACK	HON	T.B.D.			CONFERENCE ROOM
DC-097	BOW FRONT DESK SHELL	HON / H10596	72" W X 36" D X 29" H			
DC-103	CHAIR - WOOD W/RACK UNDER SEAT	JASPER CHAIR	18"			
DC-165	TABLE - LIBRARY STUDY TABLE	MARK PRODUCTS	42" W X 42" D X 29" H			
DC-177	TABLE - COMPUTER	VIROCO #873060	24" W X 60" D X ADJ HEIGHT	X		
FA-009	COUCH, RECOVERY	WINCO / 855-03	24" W X 72" L X 22" H			CLINIC
FS-011	MICROWAVE, 1.2 CU. FT	KENMORE # 20-69129	21-7/8" W X 12-1/2" H X 17-7/8" D	X		
FS-013	ICE MAKER	KENMORE # 48-49599		X		
FS-027	VENDING MACHINE	FWE / PH-1826-18U	30-1/2" W X 33-1/4" D X 69" H			
LC-021	CABINET, STORAGE STEEL	HON - HSC1872.L	36" W X 18" D X 72" H			
LC-048	SAFE - 90 MIN FIRE RATED	MUTUAL GV-4520	51" H X 26" W X 29" D (190 lbs)			
LE-004	BOOK TRUCK, 3 FLAT SHELVES	BREITFORD F336	24" X 28" X 42" H			
LE-005	BOOK TRUCK, 2 SLOPING SHELVES	BREITFORD V336	37" X 18" X 42" H			
LE-006	BOOKCASE	HON - H105534	36" W X 13" D X 57-1/8" H			THICK SHELVES
LE-018	COMPUTER CARROL	INSTITUTIONAL PRODUCTS	60" W X 30" D X 36" H	X		
MM-009	SCOTCH, 3-PANEL	WINCO / 02-50-3313	69" X 81" H	X		CLINIC
NIC-001	TECHNOLOGY CENTER		T.B.D.			
NIC-1000	COMPUTER TABLE		30" X 24"	X		
NIC-4034	CEILING MOUNTED PROJECTOR		T.B.D.	X		
NIC-4035	AV SCREEN & SEAT		T.B.D.			
NIC-4000	AREA RUG		16' X 10' H			
NIC-4001	KID OTTOMAN		6' X 6'			
OF-002	FAX MACHINE	BROTHER BR12820		X		
OF-003	FILE CABINET	HON - H212C.P.	18-1/4" W X 28-1/2" D X 29" H			
OF-005	FILE CABINET VERTICAL 4-DRAWER LEGAL	HON - H214C.P.	18-1/4" W X 28-1/2" D X 52" H			
OF-006	FILE CABINET LATERAL 2-DRAWER	HON - H882.L	18" D X 36" W X 28" H			
OF-007	FILE CABINET LATERAL 5-DRAWER	HON - H885.L	36" W X 19-1/4" D X 64" H			
OF-018	SHREDDER WITH BASKET	GBC / 85X	14" W X 12" D X 18" H	X		


NOTES:
1. NOT IN CONTRACT NUMERICAL SEQUENCE REFLECT MIAMI DADE COUNTY PUBLIC SCHOOLS PRELIMINARY FF&E LIST DATED 1/20/2014.
2. COORDINATE ALL N.I.C. FF&E WITH MDCPS FOR FINAL LOCATIONS AND SELECTIONS

LEGEND		MOUNTING HEIGHTS FOR INSTRUCTIONAL BOARDS	
IN-CONTRACT F.F.E.			
F-1000	TABLES	PRE-K-3RD	1'-4" AFF OVERALL 5' BOARD HGT
F-2000	WALL & BASE CABINERY	PRE-K-3RD	2'-4" AFF OVERALL 4' BOARD HGT
F-3000	SHELVING	4th GRADE	2'-6" AFF OVERALL 4' BOARD HGT
F-3500	METAL SHELVING	MIDDLE	2'-9" AFF OVERALL 4' BOARD HGT
F-4000	EQUIPMENT	STAFF	3'-0" AFF OVERALL 4' BOARD HGT
F-5000	INSTRUCTIONAL AIDS		
F-6000	CHairs		
F-7000	SCIENCE EQUIPMENT		
F-8000	GYM EQUIPMENT		
F-9000	SITE EQUIPMENT		
IN-CONTRACT CASEWORK		TYPE OR STYLE refer to DWGS, A-222 for details	
B	BASE	O	OPEN
C	CABINET	P	PANEL
D	DRAWERS	Q	COMBINATION LOWER/UPPER
E	VENTED	R	COUNTER
F	FULL LENGTH-WALL-WALL	S	SLOPING-SHELVES
G	DISH CABINET/LINENS	T	TABLE
K	DESK	U	UPPER
L	SPECIAL OR CUSTOM	V	VERTICAL DIVIDERS
M	WALLBOXES	W	WALL
N	FALSE PANEL		


- GENERAL NOTES**
- FOR TOILET ROOMS, REFER TO DRAWINGS A-712 & A-713 FOR ENLARGED PLANS AND ELEVATIONS.
 - FOR TOILET ROOM PROGRAM SPACE ACCESSORIES AND FOR GENERAL MOUNTING HEIGHTS, REFER TO SHEETS A-700.
 - FOR CASEWORK, ELEVATIONS AND DETAILS, REFER TO DRAWINGS A-750 & A-751.
 - REFER TO THE FOLLOWING SPECIFICATION SECTIONS FOR MANUFACTURERS AND MODEL NUMBERS NOT SHOWN ABOVE:
10100 Visual Display Board And Display Cases (including tackboards)
10125 Tackable Wall System
10165 Plastic Toilet Partitions And Shower Screens
10190 Outside Curtain Track
10400 Identifying Devices
10505 Metal Lockers And Benches
10520 Fire Protection Specialties
10675 Metal Storage Shelving And Cabinets
11450 Residential Appliances
12354 Laboratory Casework And Equipment
12364 Medical Equipment Storage
12710 Auditorium Seating
12760 Telescoping Gymnasium Seating
 - ALL UPPER AND LOWER CABINETS TO HAVE ROUNDED CORNERS.
 - ALL INTERIOR FINISHES SHALL COMPLY WITH THE REQUIRED CLASSIFICATIONS AS DESCRIBED IN THE FLORIDA FIRE PREVENTION CODE. ALL INTERIOR FINISHES TO BE CLASS "A".
 - PROVIDE ALL NECESSARY BLOCKING AND BACKING AT PARTITIONS ALONG ALL CABINET AREAS AS REQUIRED TO SUSTAIN 75LBS PER LINEAR FEET OF SHELVING/CASEWORK AS PER AWH STANDARDS. SEE SPECIFICATIONS.

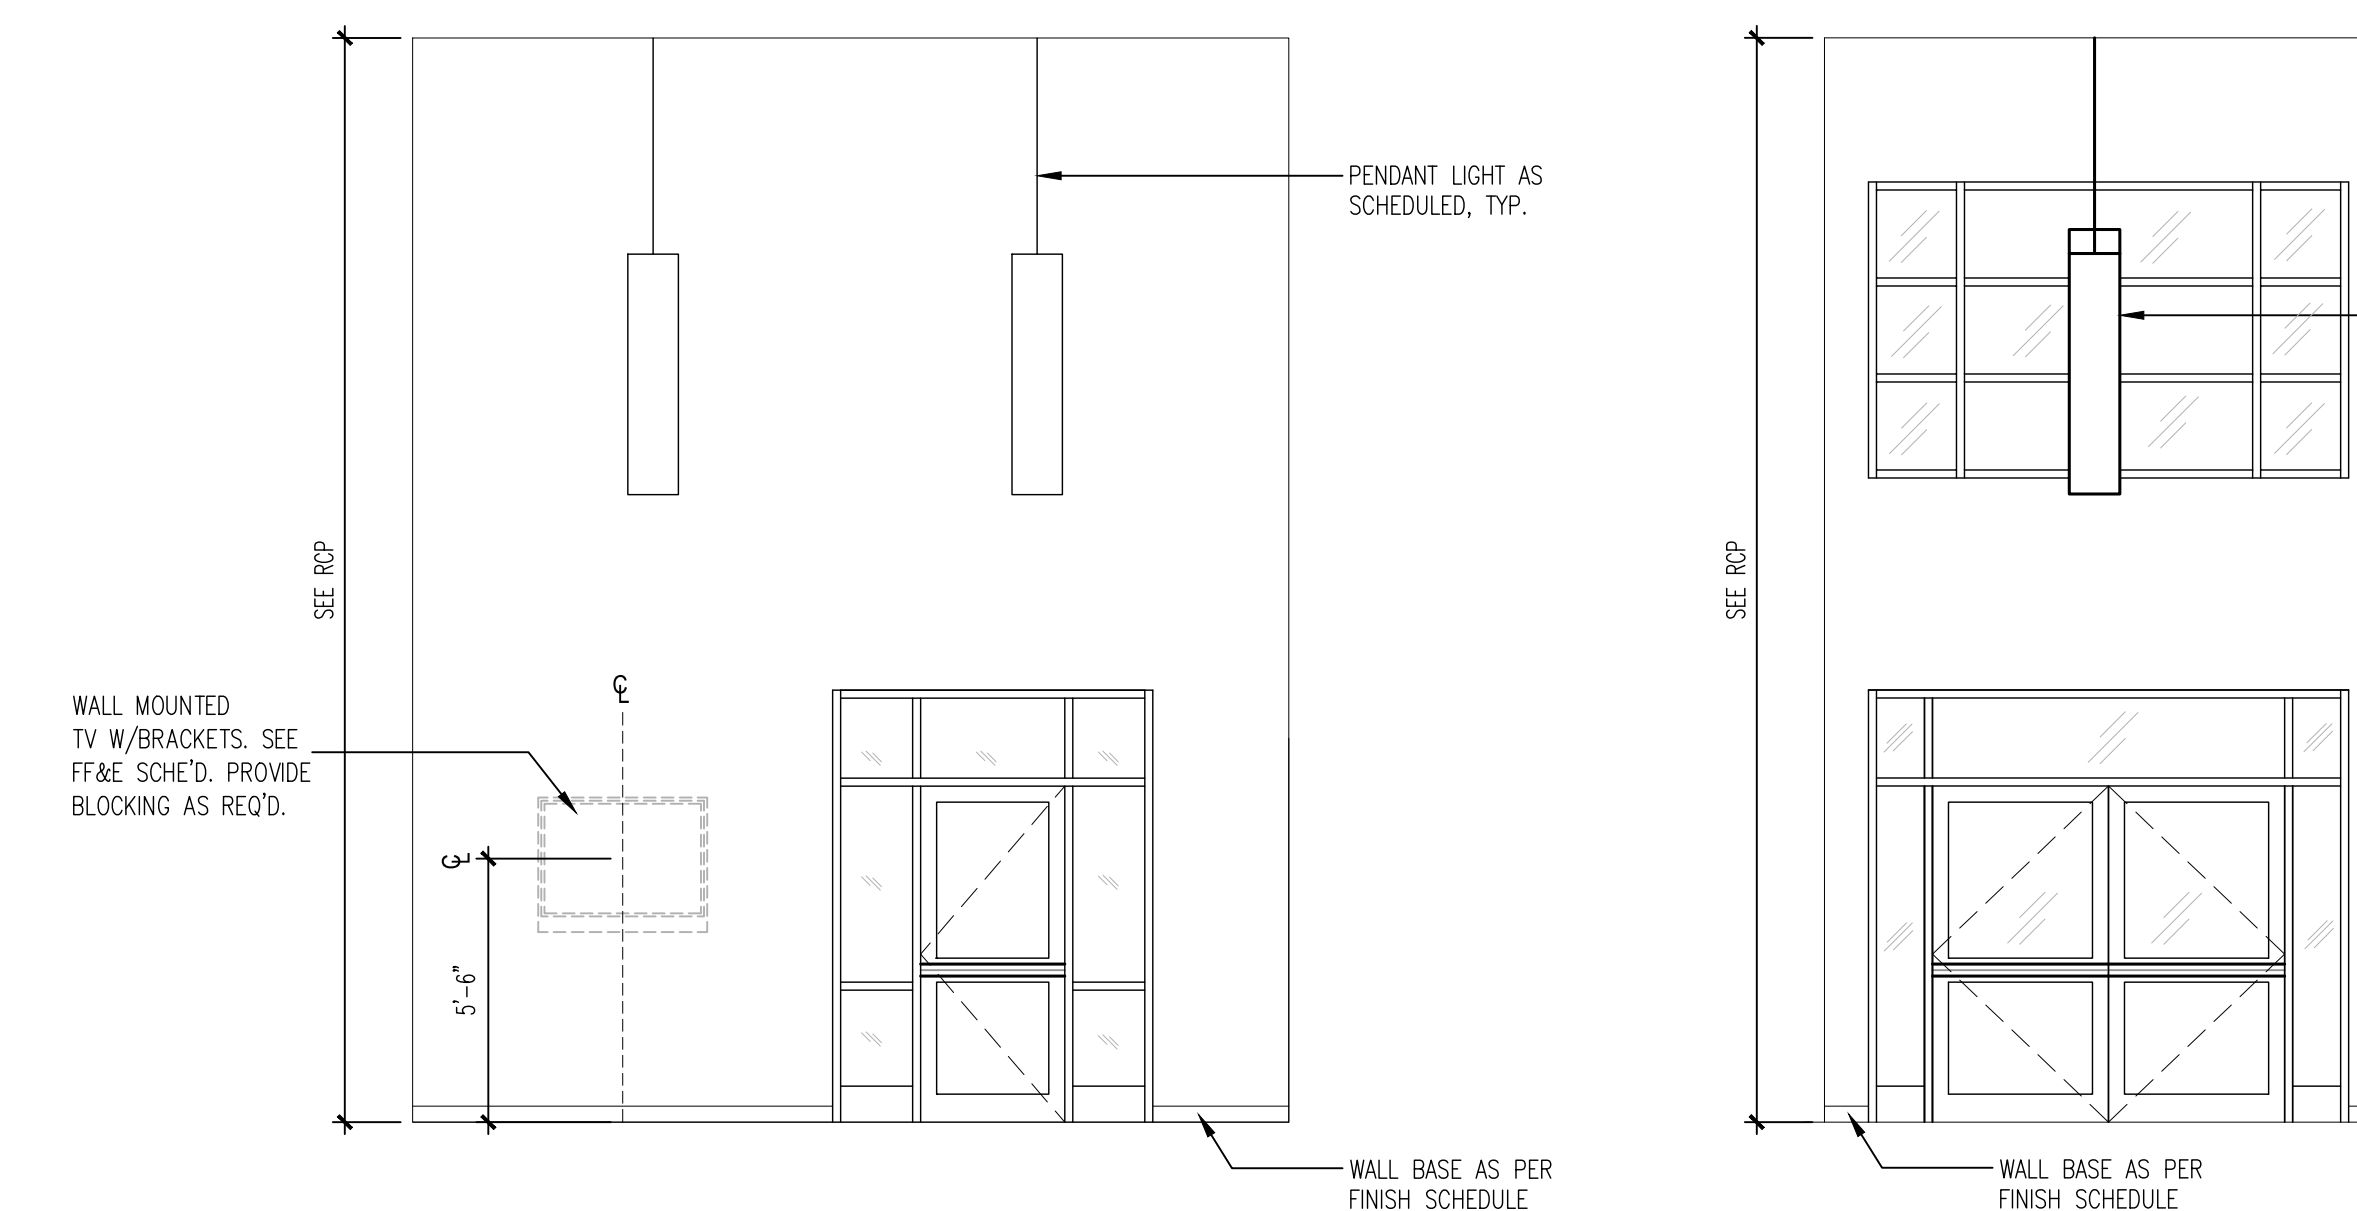


2 SALONETA ADMINISTRATION OFFICE ENTRY
A-702 Scale: 1/4" = 1'-0"

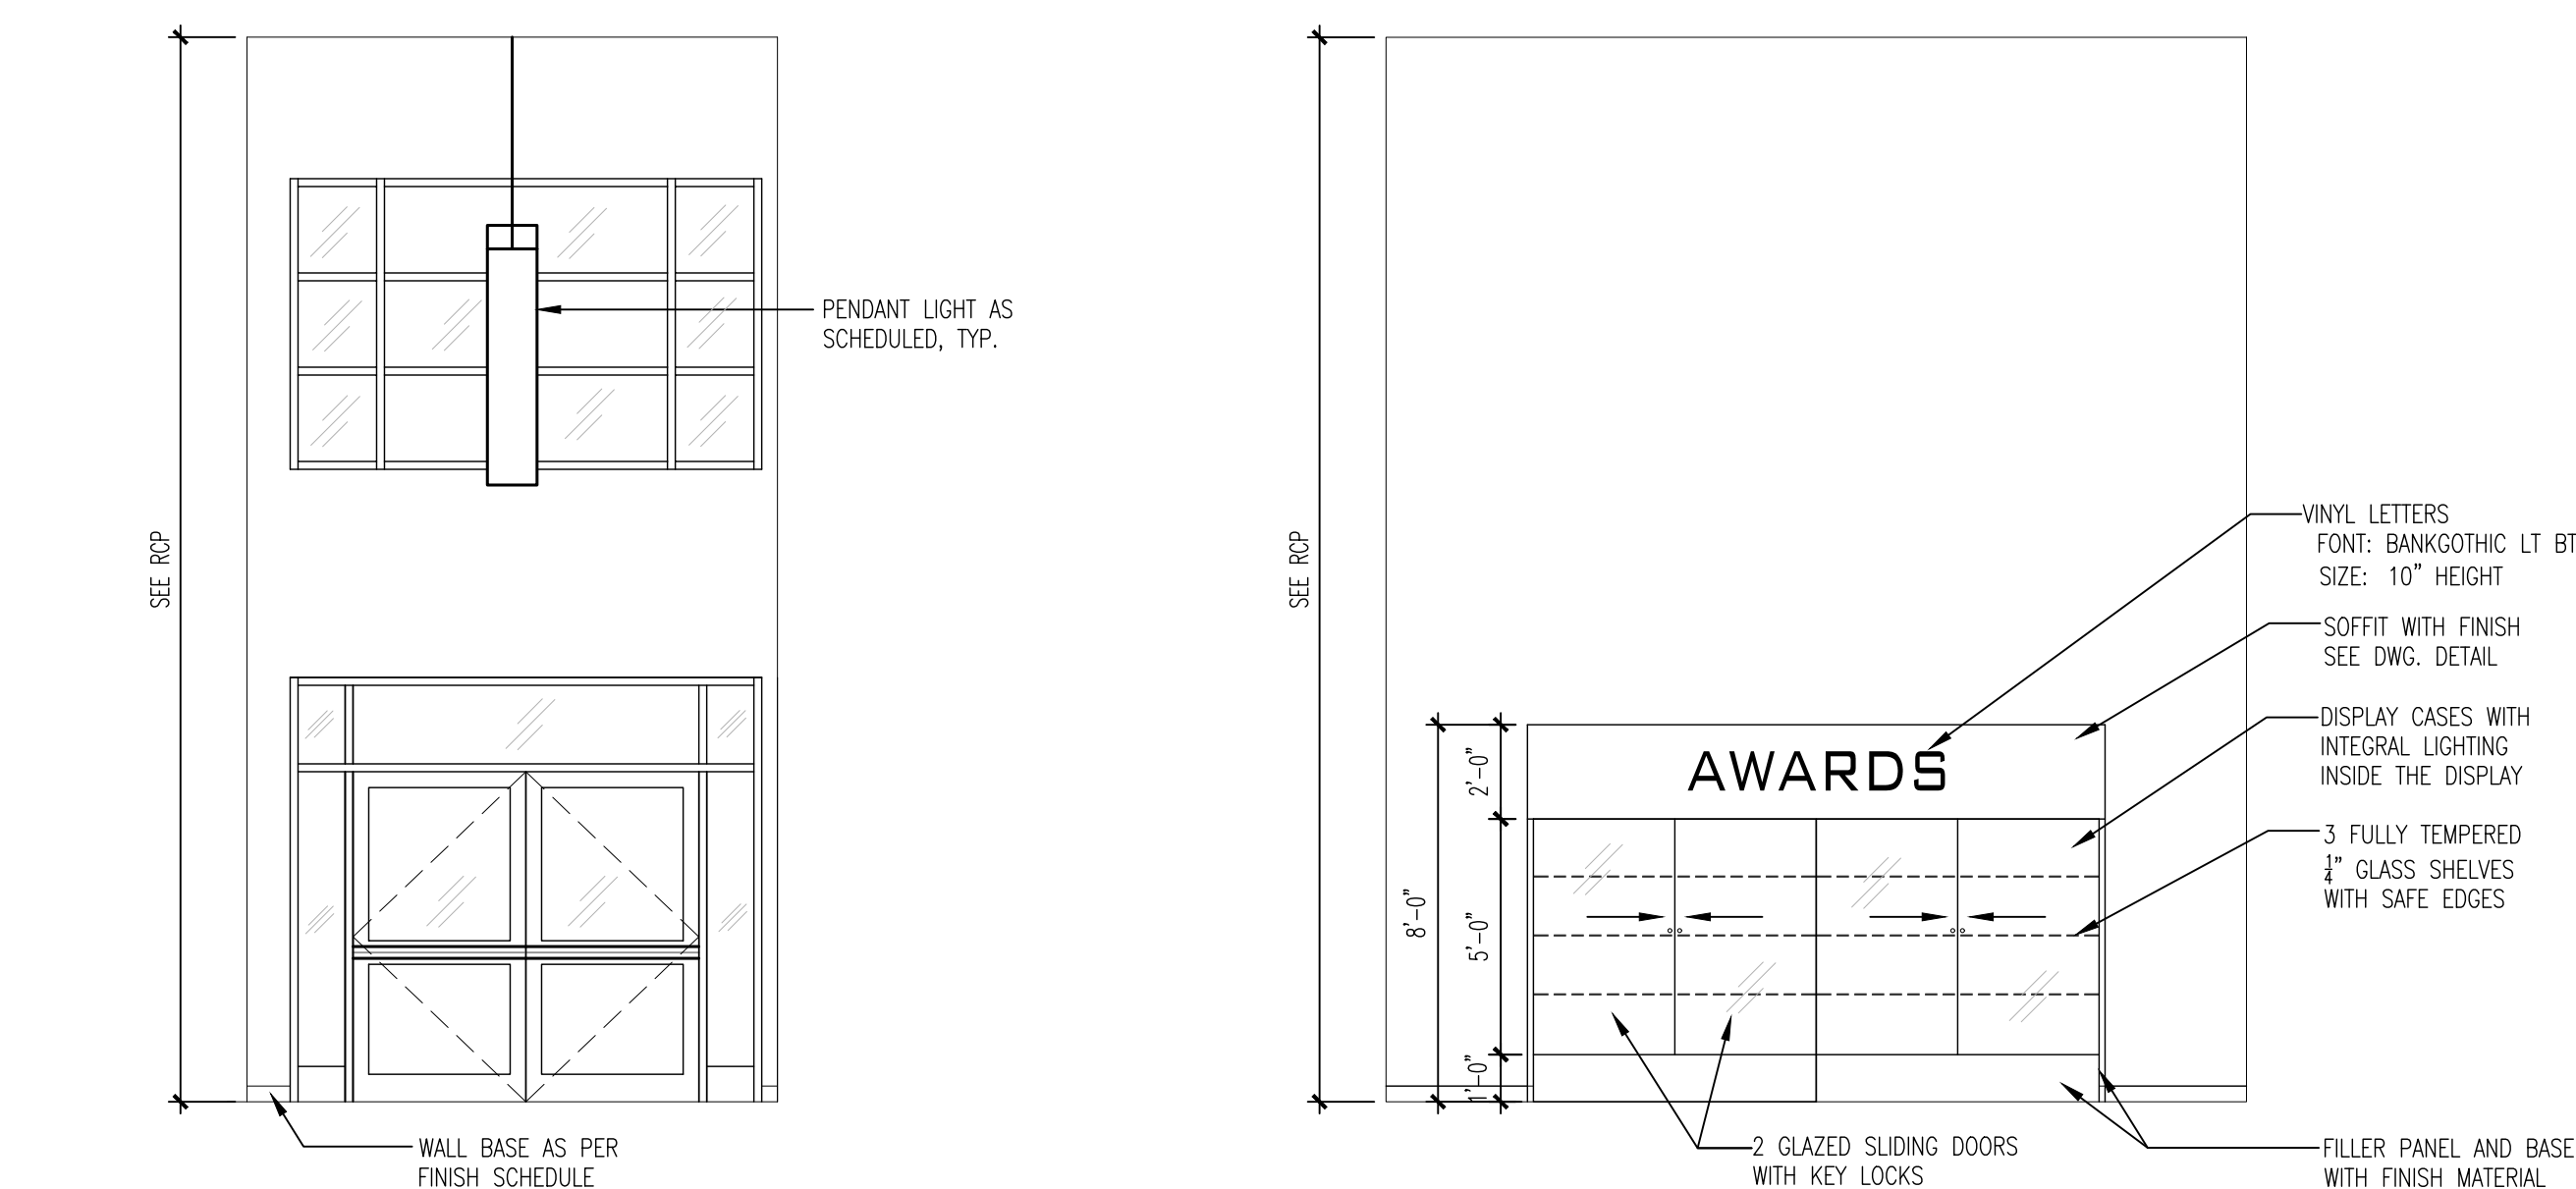


3 SALONETA SCHOOL MAIN ENTRY
A-702 Scale: 1/4" = 1'-0"

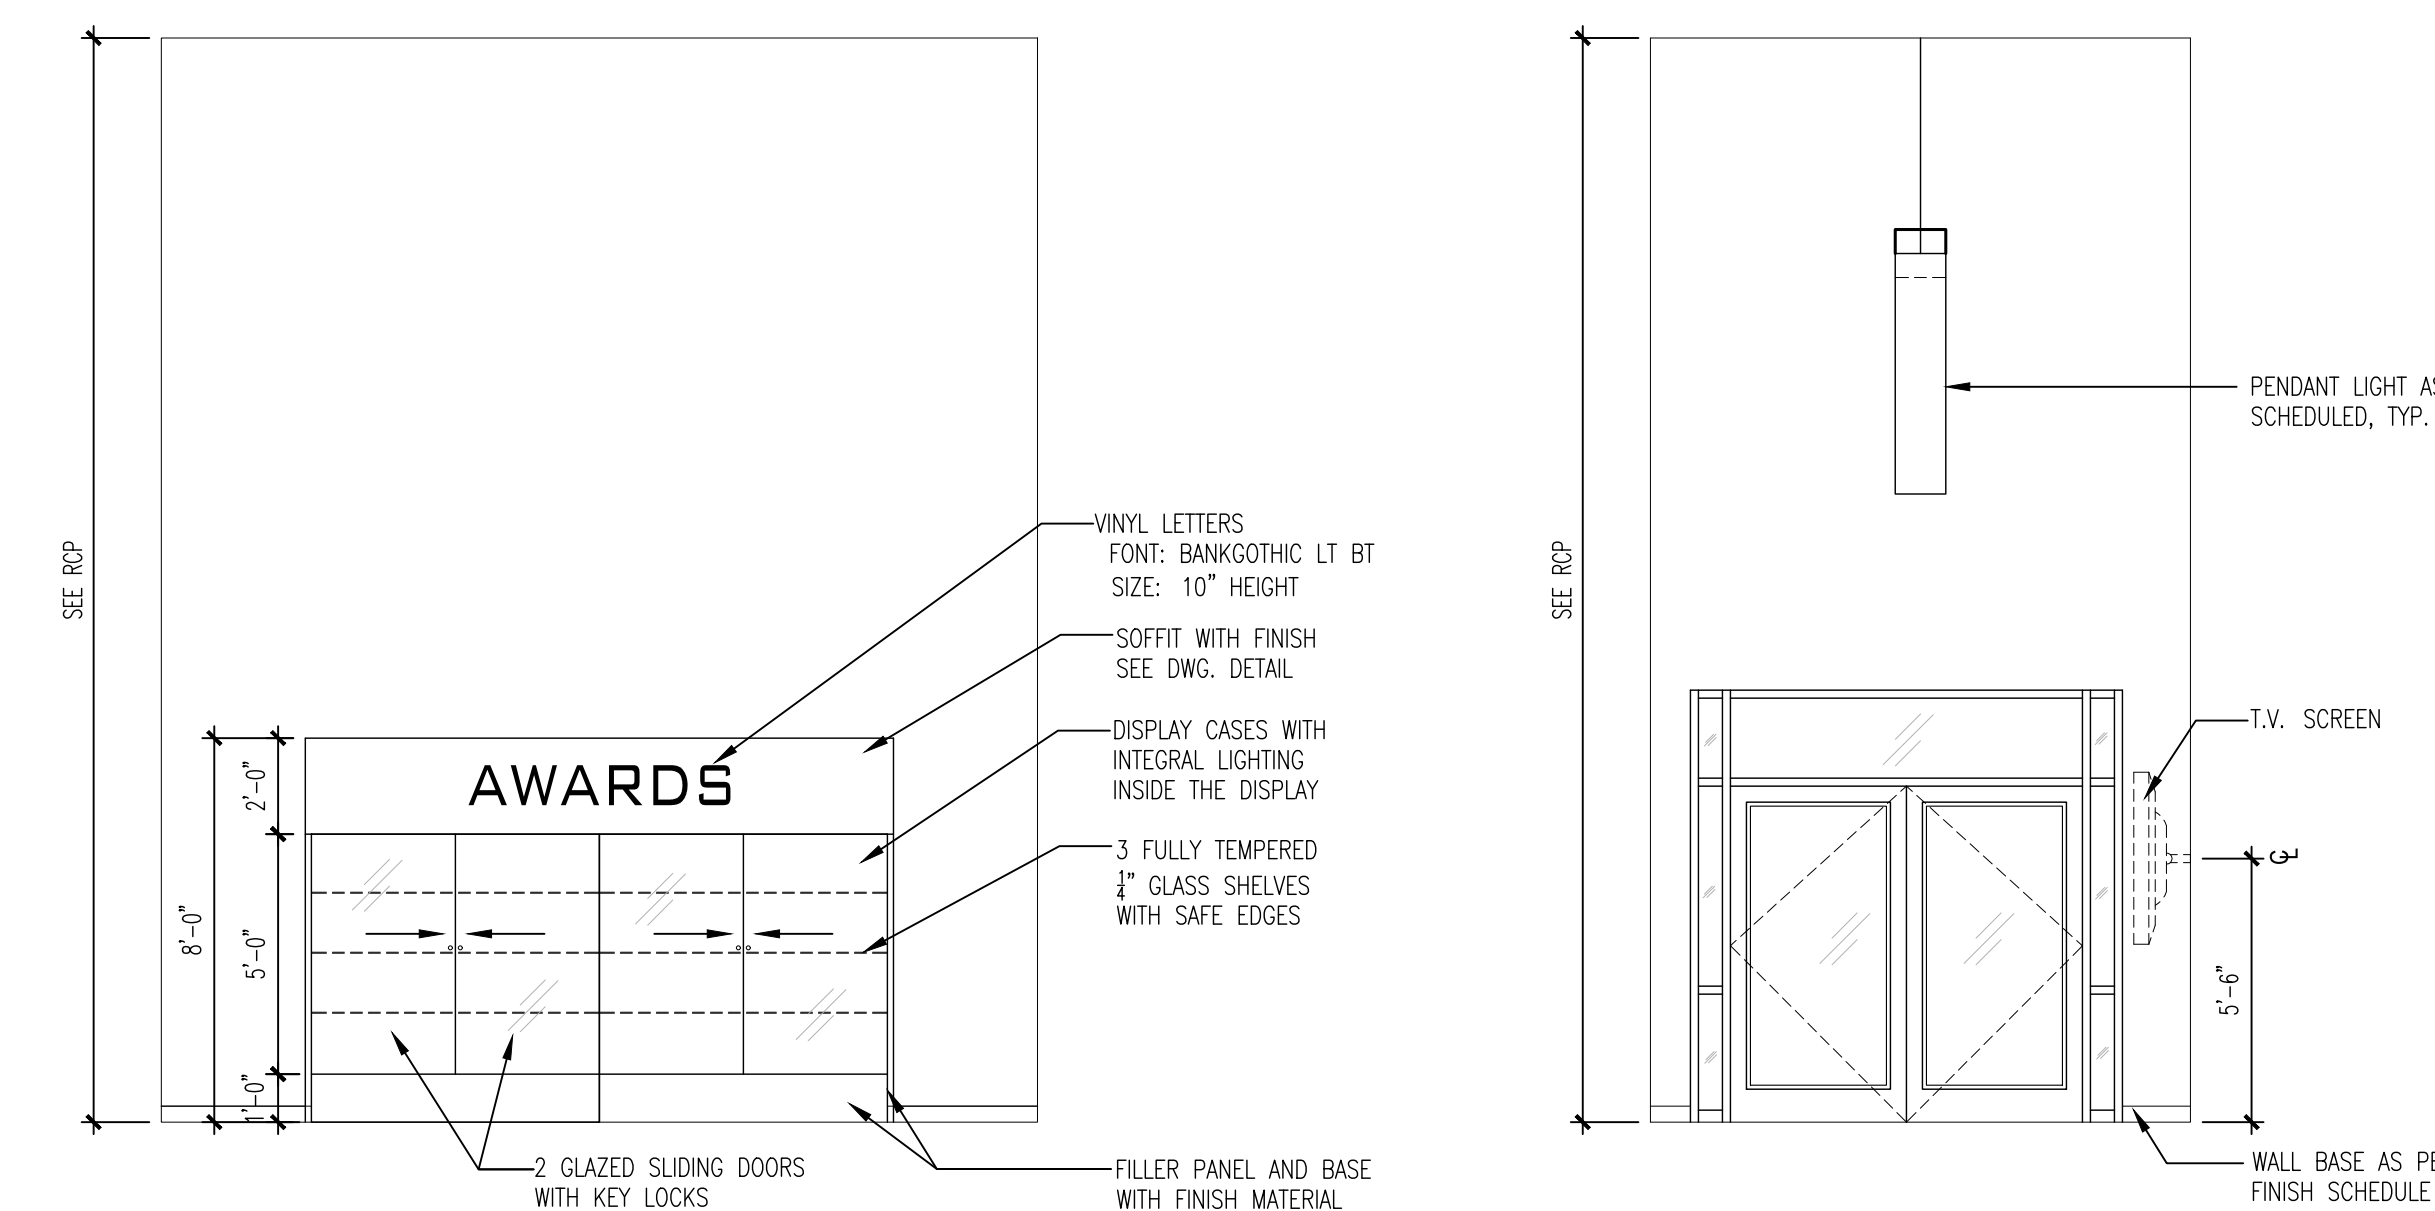


4 SALONETA WAITING AREA
A-702 Scale: 1/4" = 1'-0"

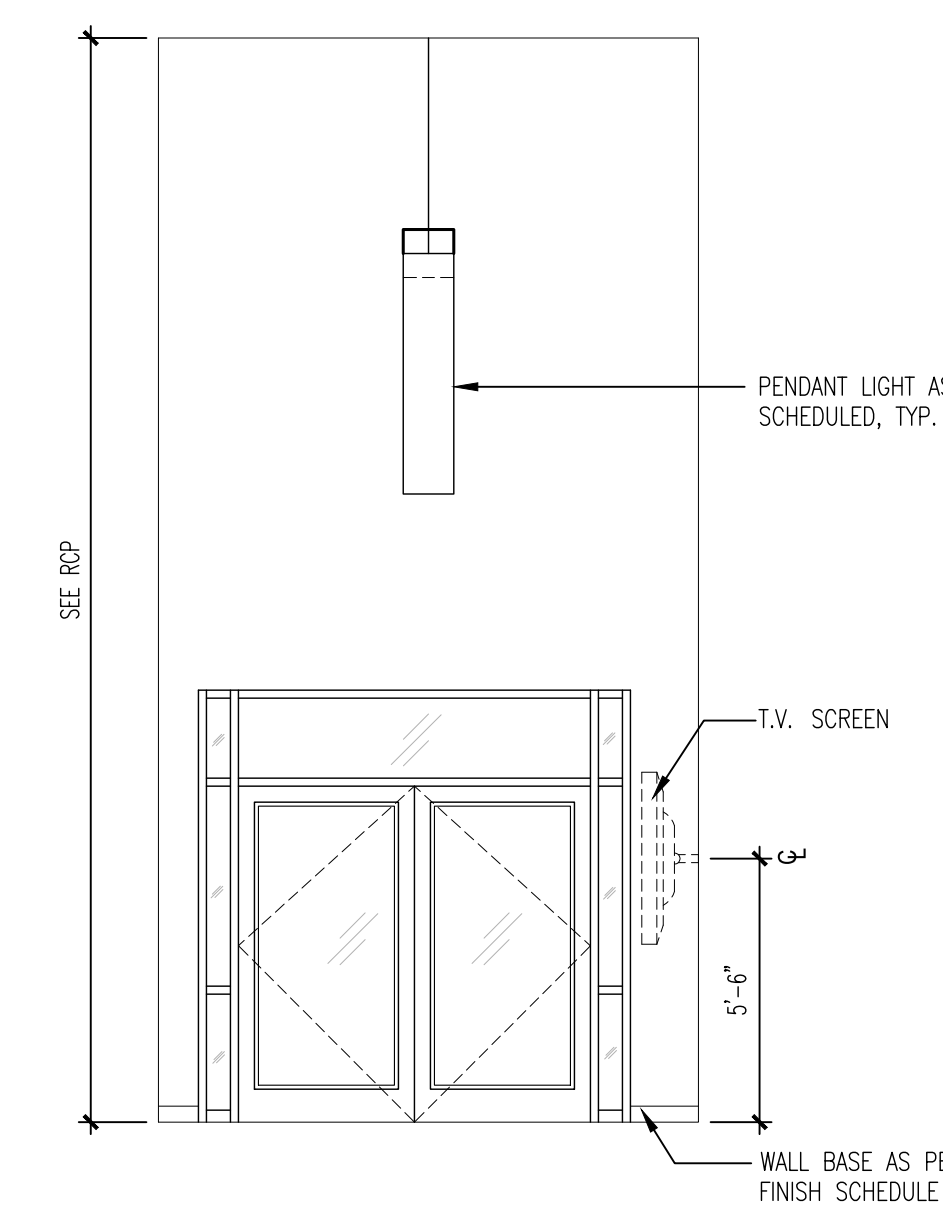


5 SALONETA MAIN ENTRY
A-702 Scale: 1/4" = 1'-0"

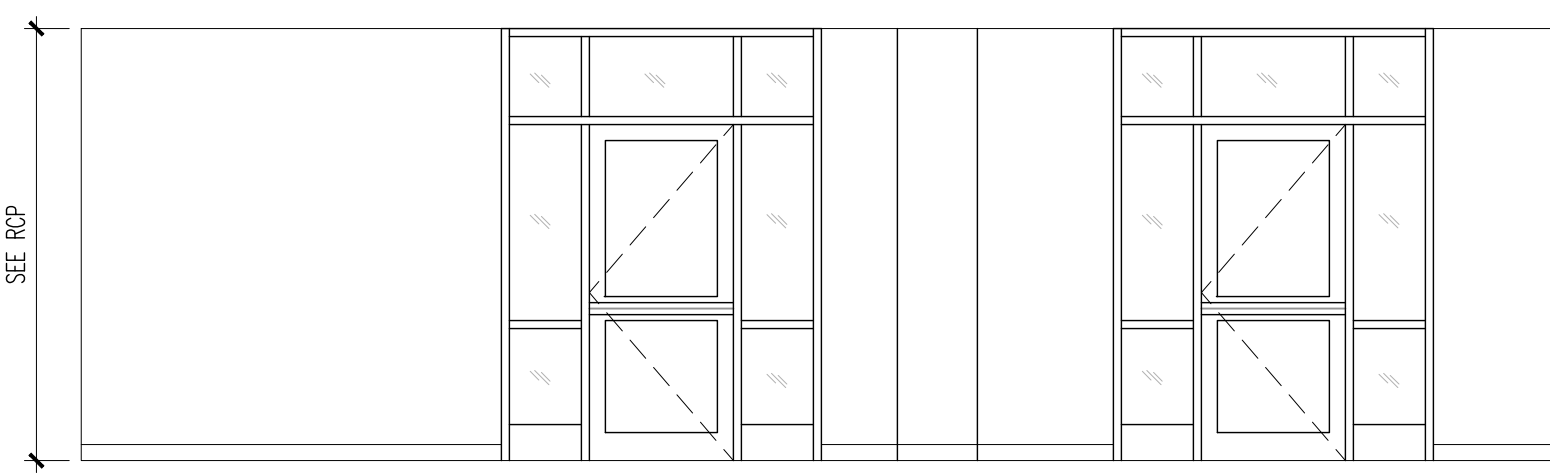


1 ADMINISTRATION EXIT
A-703 Scale: 1/4"= 1'-0"

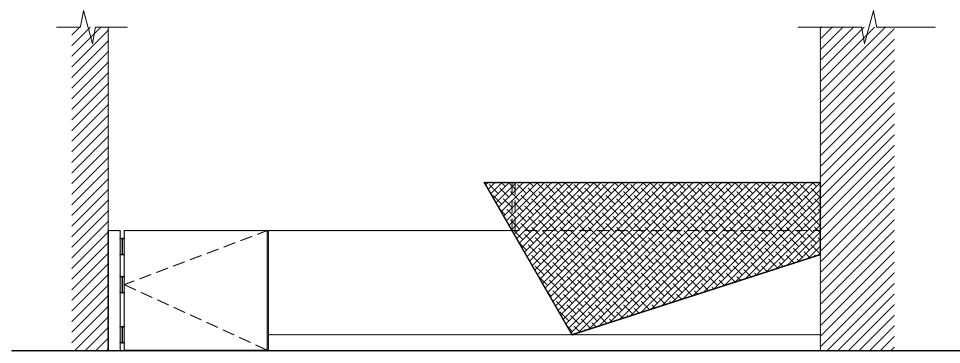


2 RECEPTION DESK
A-703 Scale: 1/4"= 1'-0"

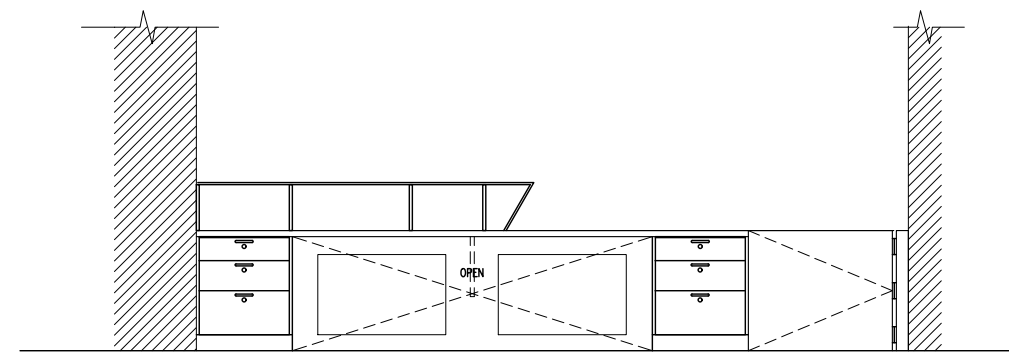


3 RECEPTION DESK
A-703 Scale: 1/4"= 1'-0"

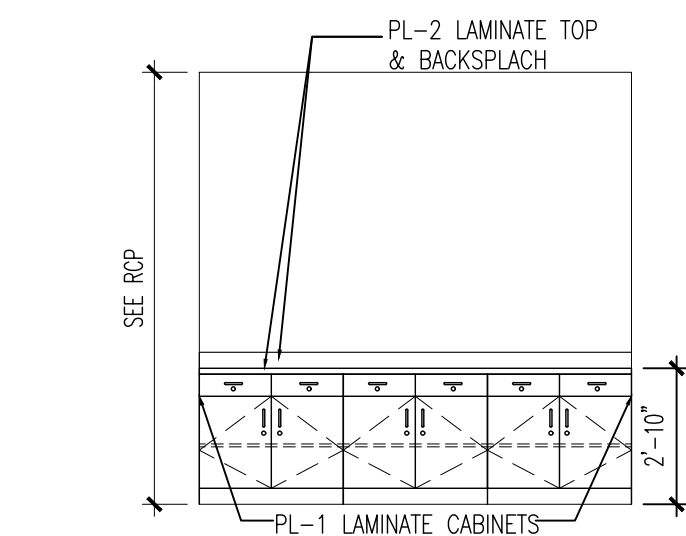


4 PRODUCTION WORKROOM
A-703 Scale: 1/4"= 1'-0"

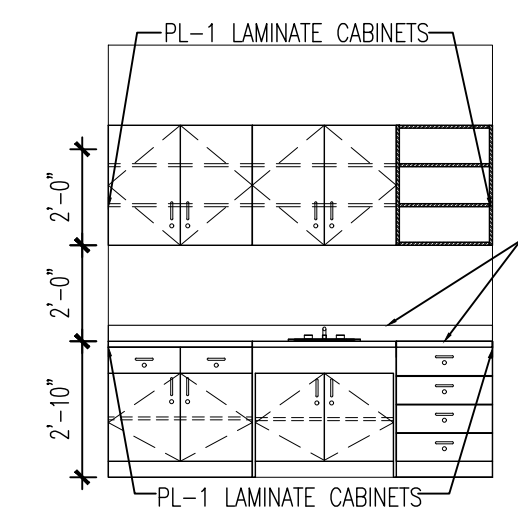


5 PRODUCTION WORKROOM
A-703 Scale: 1/4"= 1'-0"

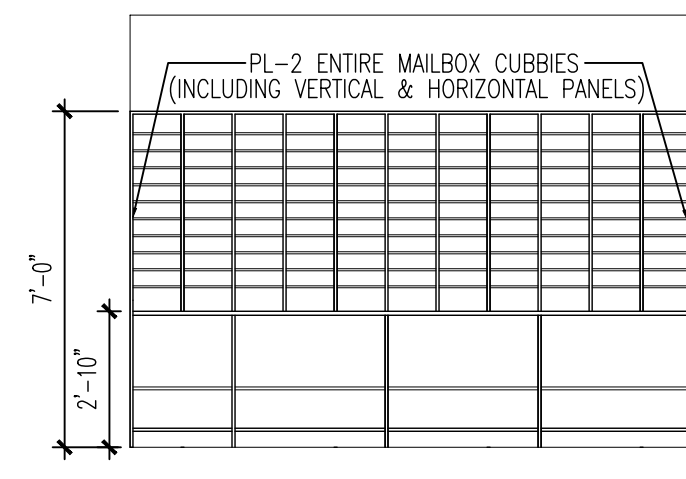


6 PRODUCTION WORKROOM
A-703 Scale: 1/4"= 1'-0"

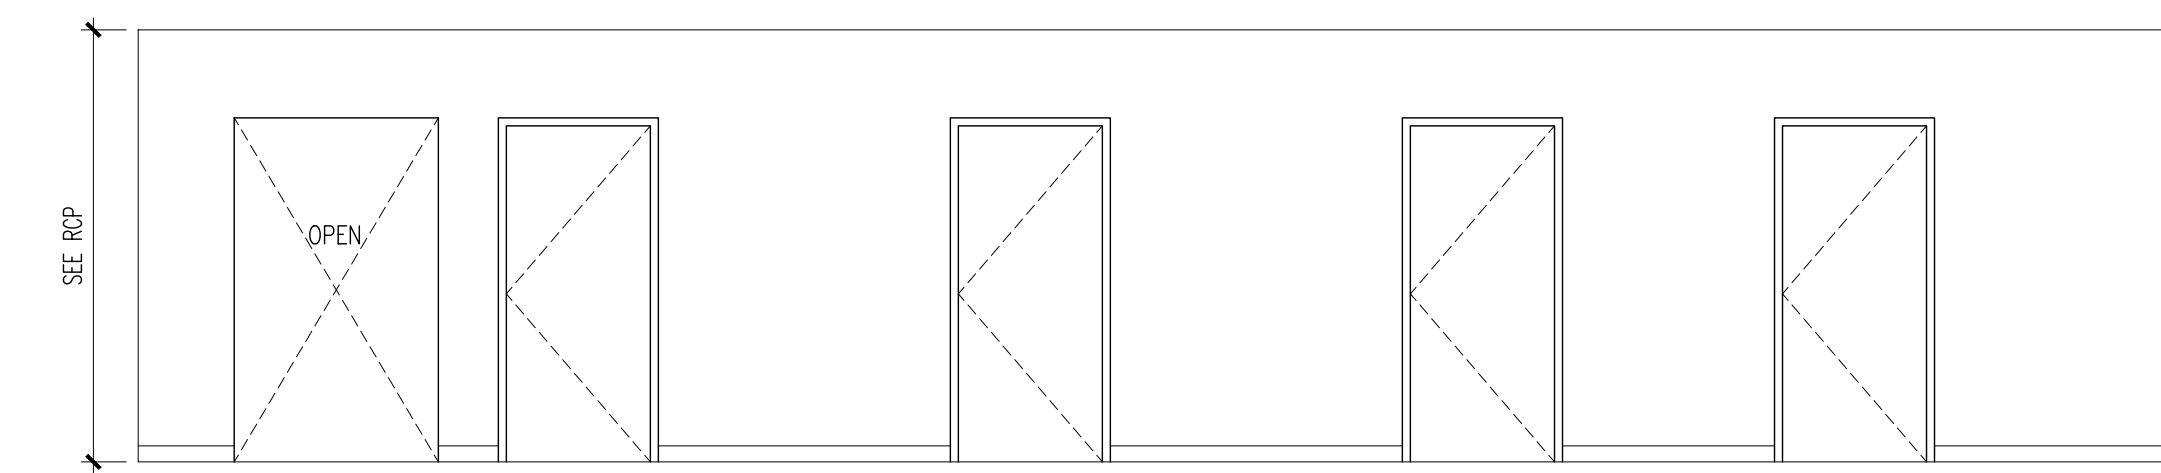


7 STUDENT SERVICES
A-703 Scale: 1/4"= 1'-0"

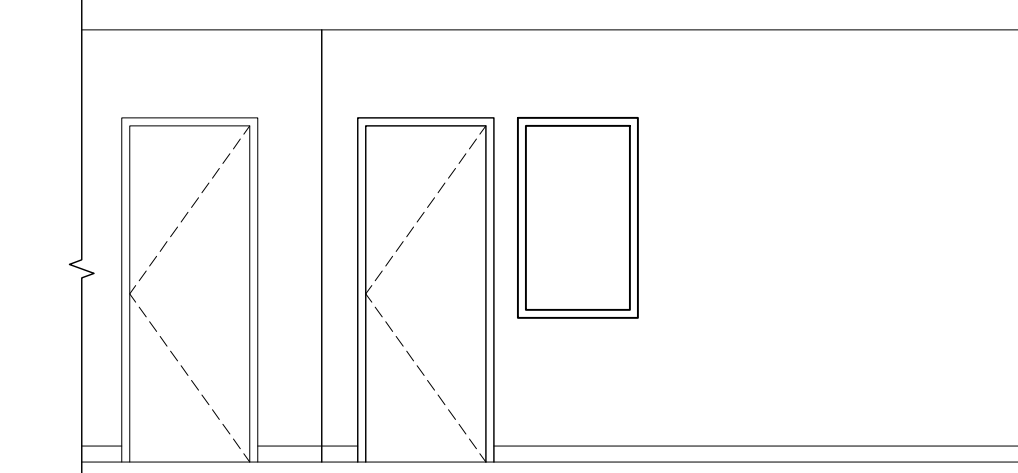


8 STUDENT SERVICES
A-703 Scale: 1/4"= 1'-0"

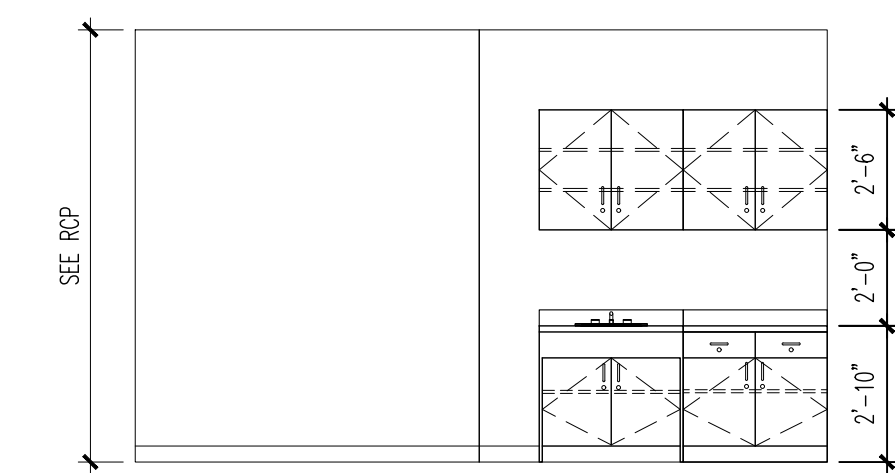


9 CLINIC
A-703 Scale: 1/4"= 1'-0"

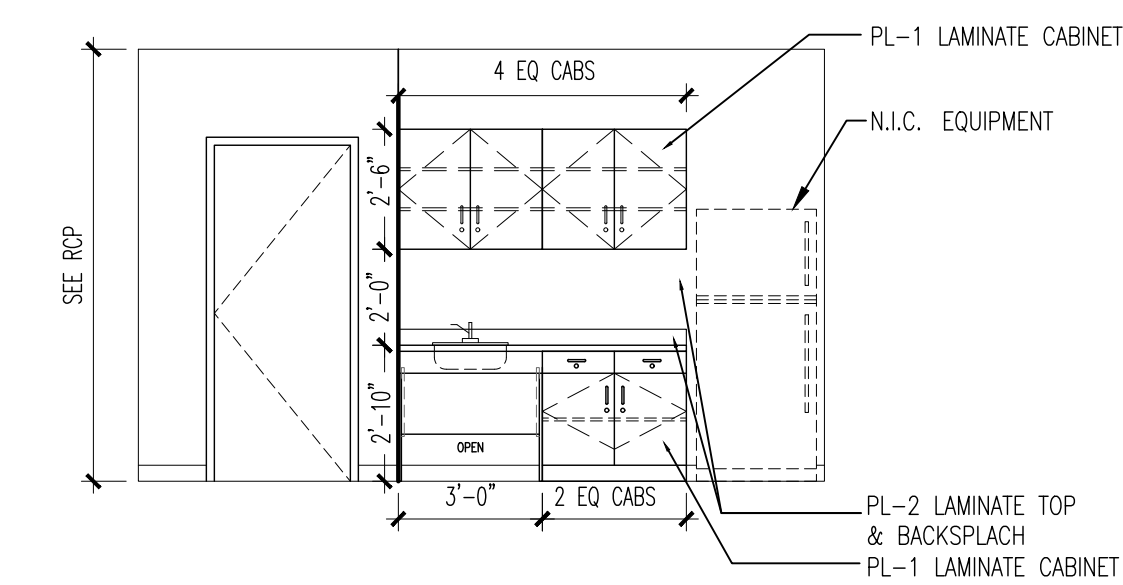


10 TEACHER DINING
A-703 Scale: 1/4"= 1'-0"

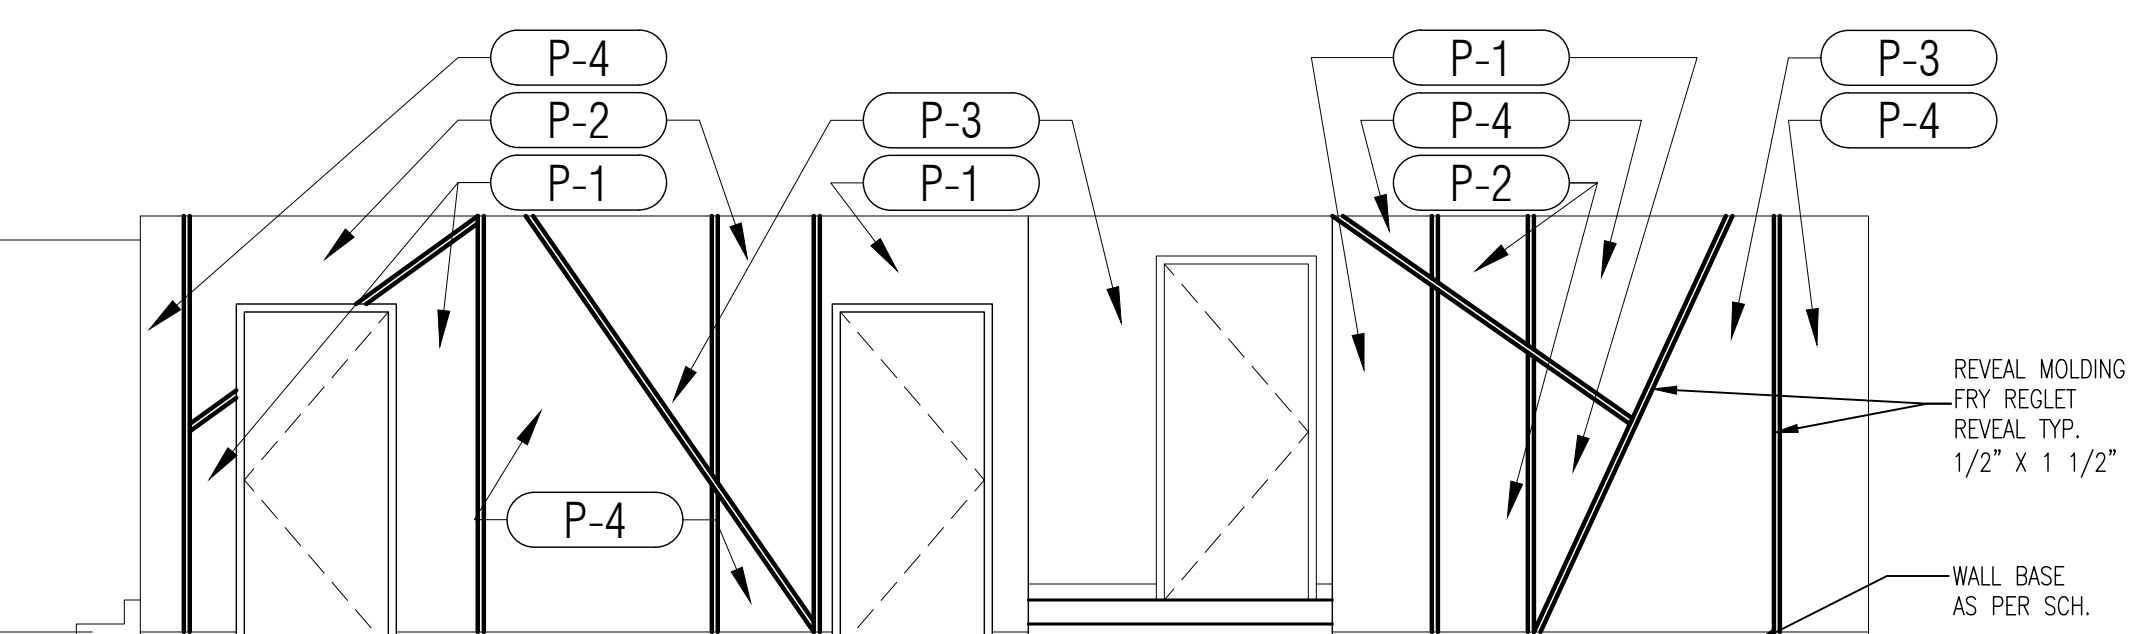

11 DINING PLAZA
A-703 Scale: 1/4"= 1'-0"

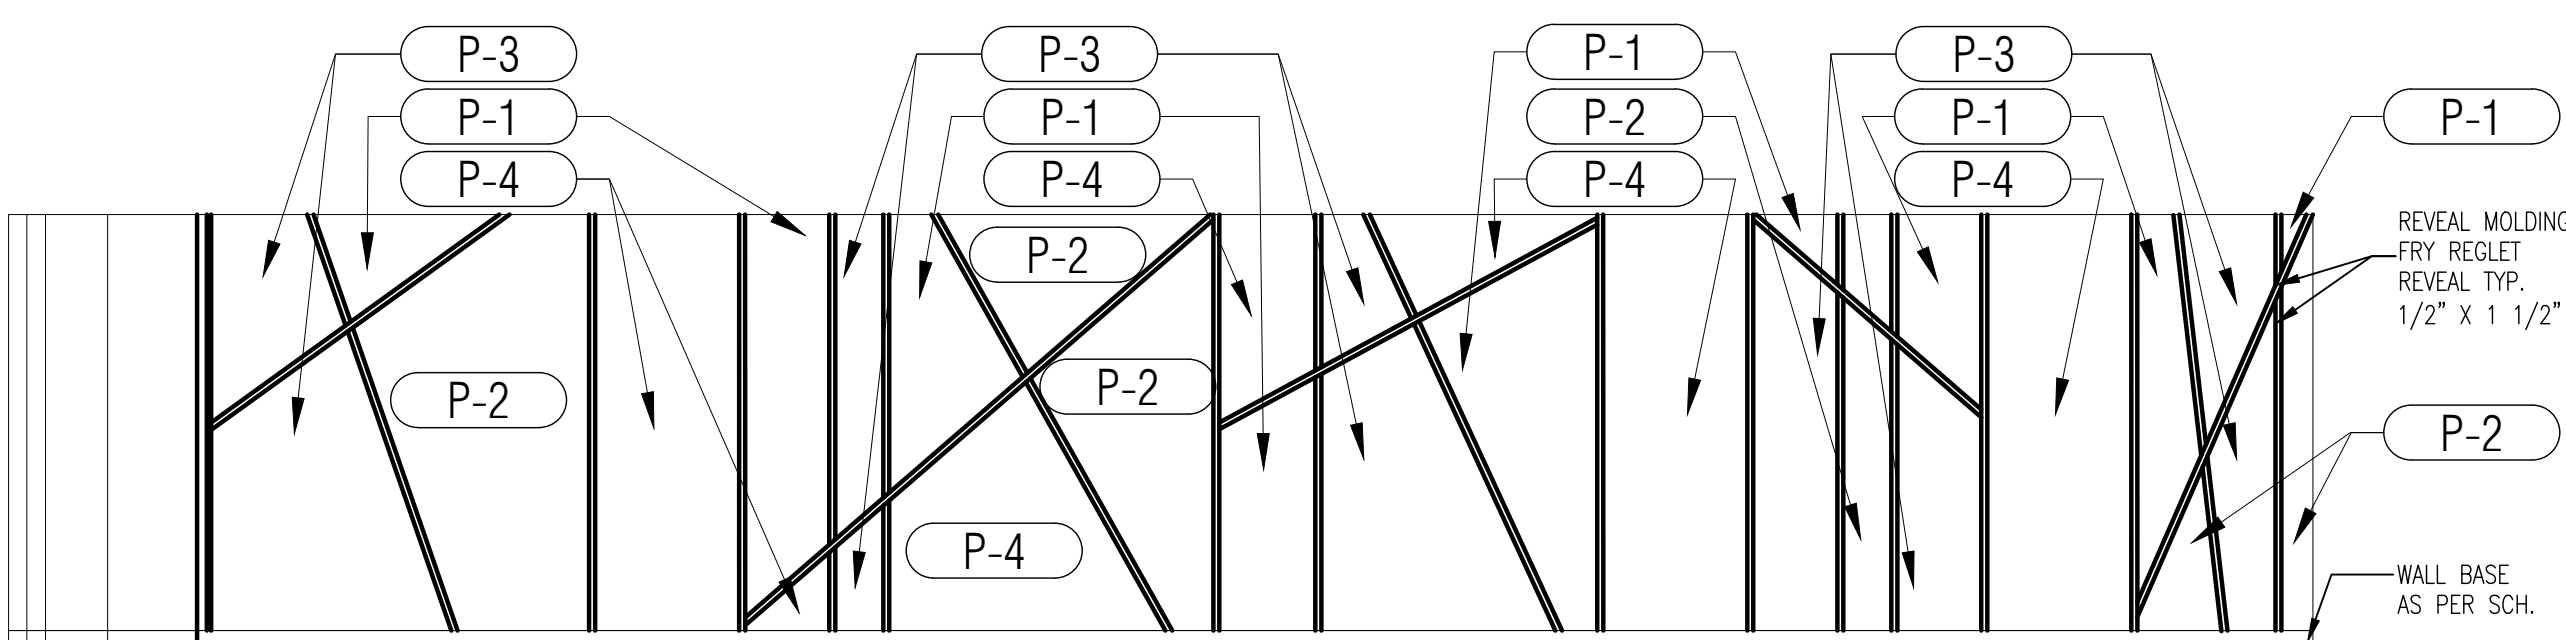

12 DINING PLAZA
A-703 Scale: 1/4"= 1'-0"

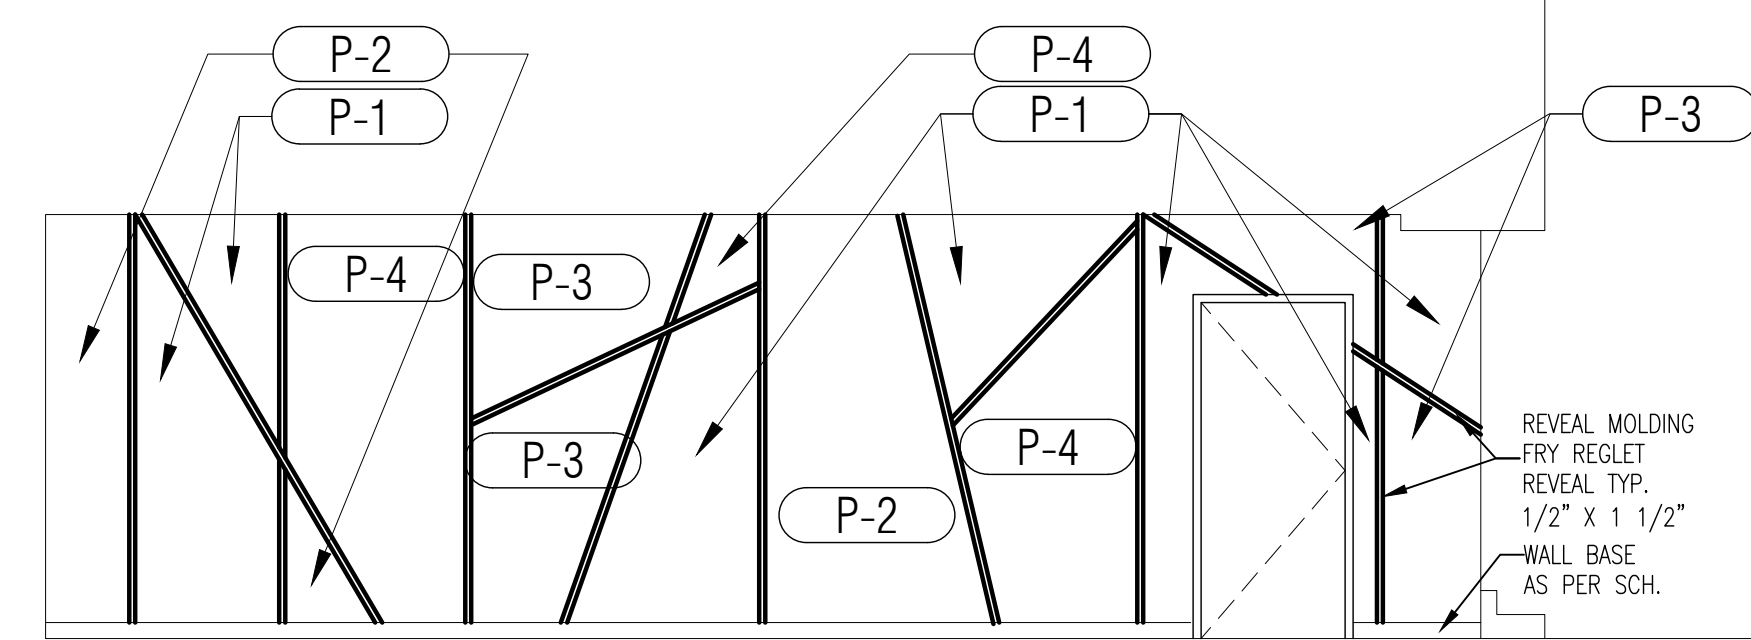

13 DINING PLAZA
A-703 Scale: 1/4"= 1'-0"

FURNITURE, FIXTURES & EQUIPMENT SCHEDULES


IN CONTRACT ITEMS (IC)						
NO.	DESCRIPTION	MANU./MODEL	SIZE	ELECT	PLUMB	GAS
F-3548	HEAVY DUTY ADJUSTABLE SHELVING		36" x 18" x 84" H			
F-4001	TV HUB		36" W x 8" D x 36" H	X		
F-4003	CEILING MOUNTED PROJECTOR BRACKET			X		
F-4008	FIRE SAFETY BLANKET	LARSEN NO. FB 68-6 SERIES	68" H x 8-1/4" W x 4" D			
F-4011	LIBRARY SHELVING		36" W x 12" D x 42" H			
F-4012	LIBRARY SHELVING		36" W x 12" D x 30" H			
F-4013	LIBRARY SHELVING		36" W x 12" D x 66" H			
F-4014	ADJUSTABLE LIBRARY SHELVING		36" x 18" x 84" H			
F-4200	TV HUB		36" W x 8" D x 36" H	X		
F-4035	MOTORIZED PROJECTOR SCREEN			X		
F-4036	OVERHEAD TRACK LIGHTING			X		
F-4198	CLOCK SPEAKER			X		
F-5000	TACKBOARD	CLARIDGE OR EQUAL	4'-0" x 4'-0"			W/MARKER TRAY AND MAP RAIL
F-5035	COMBINATION TACKBOARD/MARKERBOARD	CLARIDGE OR EQUAL	6'-0" x 4'-0"			
F-5037	MARKERBOARD	CLARIDGE OR EQUAL	4'-0" x 4'-0"			
F-5066	COMBINATION TACKBOARD/MARKERBOARD	CLARIDGE OR EQUAL	8'-0" x 4'-0"			
F-8001	TEACHER CALL BOX			X		
F-9000	BOOK DETECTION SYSTEM	CHECKPOINT	SEE MANUFACTURER SPEC.	X		MODEL: LIBERTY FX_MEDIA AREA

NOT IN CONTRACT ITEMS (NIC)						
NO.	DESCRIPTION	MANU./MODEL	SIZE	ELECT	PLUMB	GAS
AV-676	TELEVISION AND BRACKET INSTALLATION	TROXELL INSTALLER		X		
AV-677	PROJECTION TABLE CART	PROMETHEAN / ARMTSTBBJST	24" x 18" x 34" H	X		
AV-678	ACTIVEBOARD TOUCH	PROMETHEAN / ARMTSTBBJST	71" x 4" H	X		
AV-621	CLASSROOM SOUND SYSTEM	ACHEVER MDL#CAE-20MPAL	T.B.D.	X		
AV-622	CLASSROOM EXTERNAL TUNER/ADAPTER	ACHEVER MDL#CAE-20MPAL	T.B.D.	X		
AV-632	PROJECTION SYSTEM	NEC / M311X	T.B.D.	X		
AV-674	TV UNIVERSAL 30"	TOUCHSCREEN / 50L1350U		X		
AV-676	TV UNIVERSAL WALL MOUNT	PEPPERLESS/SA740P AND/OR ST650		X		
AV-677	TELEVISION 32" FLAT PANEL	SAMSUNG / MD32C		X		
AV-680	MIC BOX			X		
AV-681	CAMERA			X		
AV-682	PROMPTER			X		
AV-683	CONSOLE (3 STATIONS)			X		
AV-684	TV RACK	70" H x 24" W x 26" D		X		
CO-020	COMPUTER, MAINSTREAM WITH MONITOR	T.B.D.		X		
CO-025	LASER PRINTER, BASIC NETWORK DUPLICATING	HP / P2055DN 070-1104	T.B.D.	X		
DC-004	CHAIR, DISCOVERY SERIES ERGONOMIC	ARTICO-BELL / D10B	16"			SEAT AND LEG T.B.D.
DC-006	CHAIR, DISCOVERY SERIES ERGONOMIC	ARTICO-BELL / D10A	18"			SEAT AND LEG T.B.D.
DC-008	CHAIR, EXECUTIVE HIGH BACK	HON - 2071BK	T.B.D.			
DC-009	CHAIR - PADDED SEAT	HON - H1081	T.B.D.			
DC-010	GUEST CHAIR	HON - 2304N	T.B.D.			
DC-012	LOUNGE CHAIR					
DC-013	TASK CHAIR, PNEUMATIC-BACK HEIGHT SWIVEL	HON - H7701.S				
DC-016	TEACHER'S SWIVEL CHAIR	SCHOLARSHIP / SC110P	T.B.D.			
DC-019	CRENZIA	T.B.D.	72" W x 24" D x 29-1/2" H			
DC-023	DESK - EXECUTIVE	T.B.D.	72" W x 24" D x 29-1/2" H			
DC-024	DESK - SHAPE	HON OR EQUAL 105 SERIES	66" W x 30" D x 29" H			
DC-025	STUDENT DESK					
DC-026	DESK, PUPIL OPEN FRONT	VRICO / 785MBB-MPL385	18" x 24" W x ADJ 22"-30" H			BLACK, FUSION, MAPLE TOP
DC-027	DESK, TEACHERS, SINGLE PEDESTAL	HON-H88251	48" W x 30" D			TAN METAL W/OAK LAMINATE TOP
DC-040B	TABLE-X BASE	HON - H88336.P	36" W x 36" D			
DC-040T	TABLE-SQUARE TOP	HON - H10336G	36" W x 36" D			
DC-042	TABLE-ART & PLANNING	SHAIN/SHOP-BILT #1300743705	60" W x 42" D x 36" H			
DC-043	TABLE-CLASSROOM	VRICO - 483060	30" W x 60" D x ADJ HEIGHT			BIRCH/MAPLE TOP
DC-046	TABLE - CONFERENCE	HON/DOBAN - HTL4284	84" x 42" W/36" W AT ENDS x 29" H			BIRCH/MAPLE TOP
DC-048	TABLE - END	HON - H80133	24" x 20" W x 20" H			BIRCH/MAPLE TOP
DC-054	TABLE - STUDENT	VRICO				
DC-060	TABLE/BENCH - CONVERTIBLE	MIDWEST / T88-PT 012-KK01				DINING/MULTIPURPOSE
DC-061S	STOOL, TASK, ADJUSTABLE HGT	JC WHITE/HON H7705				
DC-078	WOOD STOK	PRIDE #30				
DC-088	CHAIR EXECUTIVE MID BACK	HON				CONFERENCE ROOM
DC-097	BOW FRONT DESK SHELL	HON / H10596	72" W x 36" D x 29" H			
DC-103	CHAIR - WOOD W/RACK UNDER SEAT	JASPER CHAIR	18"			
DC-165	TABLE - LIBRARY STUDY TABLE	MARK PRODUCTS	42" W x 42" D x 29" H			
DC-177	TABLE - COMPUTER	VRICO #873060	24" W x 60" D x ADJ HEIGHT	X		
FA-009	COUCH, RECOVERY	WINCO / 855-03	24" W x 72" D x 22" H			CLINIC
FS-011	MICROWAVE, 1.2 CU. FT	KENMORE # 20-69129	21-7/8" W x 12-1/2" H x 17-7/8" D	X		
FS-013	K2C WATER	KENMORE # 46-49599		X		
FS-027	VENDING MACHINE	FWE / PH-1826-18U	30-1/2" W x 33-1/4" D x 69" H			
LC-021	CABINET, STORAGE STEEL	HON - H5C1872L	36" W x 18" D x 72" H			
LC-048	SAFE - 90 MIN FIRE RATED	MUTUAL GV-4520	51" H x 26" W x 29" D (1930 lbs)			THICK SHELVES
LE-004	BOOK TRUCK, 3 FLAT SHELVES	BREITFORD E336	24" x 28" x 42" H			
LE-005	BOOK TRUCK, 6 SLOPING SHELVES	BREITFORD V336	37" x 18" D x 42" H			
LE-006	BOOKCASE	HON - H105534	36" W x 13" D x 57-1/8" H			
LE-018	COMPUTER CARROL	INSTITUTIONAL PRODUCTS	60" W x 30" D x 36" H	X		
MM-009	SCREEN, 3-PANEL	WINCO / 02-50-3313	60" x 61"	X		CLINIC
NIC-0001	TECHNOLOGY CENTER		T.B.D.			
NIC-1000	COMPUTER TABLE		30" x 24"	X		
NIC-4034	CEILING MOUNTED PROJECTOR		T.B.D.	X		
NIC-4035	AV SCREEN & BRACKET		161" x 10" H	X		
NIC-4000	AREA RUG		6' x 6'			
NIC-4001	KID OTTOMAN					
OF-002	FAX MACHINE	BROTHER BR12820		X		
OF-003	FILE CABINET	HON - H212C.P.	18-1/4" W x 28-1/2" D x 29" H			
OF-005	FILE CABINET VERTICAL 4-DRAWER LEGAL	HON - H214C.P.	18-1/4" W x 28-1/2" D x 52" H			
OF-006	FILE CABINET LATERAL 2-DRAWER	HON - H882.L	18" D x 36" W x 28" H			
OF-007	FILE CABINET LATERAL 5-DRAWER	HON - H885.L	36" W x 19-1/4" D x 64" H			
OF-018	SHREDDER WITH BASKET	GBC / 85X	14" W x 12" D x 18" H	X		


NOTES:
1. NOT IN CONTRACT NUMERICAL SEQUENCE REFLECT MIAMI DADE COUNTY PUBLIC SCHOOLS PRELIMINARY FF&E LIST DATED 1/20/2014.
2. COORDINATE ALL N.I.C. FF&E WITH MDCPS FOR FINAL LOCATIONS AND SELECTIONS

LEGEND		MOUNTING HEIGHTS FOR INSTRUCTIONAL BOARDS	
TYPE	STYLE	PRE-K-3RD	4th GRADE
B	BASE	1'-4"	2'-4"
C	CABINET	2'-4"	2'-8"
D	DRAWERS	2'-8"	2'-8"
E	VENTED	2'-8"	2'-8"
F	FULL LENGTH-WALL-WALL	2'-8"	2'-8"
G	DISH CABINET/LINENS	2'-8"	2'-8"
H	DESK	2'-8"	2'-8"
I	SPECIAL OR CUSTOM	2'-8"	2'-8"
J	WALLBOXES	2'-8"	2'-8"
K	FALSE PANEL	2'-8"	2'-8"
L	STAFF	2'-8"	2'-8"
M	STAFF	2'-8"	2'-8"
N	STAFF	2'-8"	2'-8"
O	STAFF	2'-8"	2'-8"
P	STAFF	2'-8"	2'-8"
Q	STAFF	2'-8"	2'-8"
R	STAFF	2'-8"	2'-8"
S	STAFF	2'-8"	2'-8"
T	STAFF	2'-8"	2'-8"
U	STAFF	2'-8"	2'-8"
V	STAFF	2'-8"	2'-8"
W	STAFF	2'-8"	2'-8"


- GENERAL NOTES
- FOR TOILET ROOMS, REFER TO DRAWINGS A-712 & A-713 FOR ENLARGED PLANS AND ELEVATIONS.
 - FOR TOILET ROOM PROGRAM SPACE ACCESSORIES AND FOR GENERAL MOUNTING HEIGHTS, REFER TO SHEETS A-700.
 - FOR CASEWORK, ELEVATIONS AND DETAILS, REFER TO DRAWINGS A-750 & A-751.
 - REFER TO THE FOLLOWING SPECIFICATION SECTIONS FOR MANUFACTURERS AND MODEL NUMBERS NOT SHOWN ABOVE:
 - 10100 Visual Display Board And Display Cases (including tackboards)
 - 10101 Tackable Wall System
 - 10105 Plastic Toilet Partitions And Shower Screens
 - 10190 Cubicle Curtain Track
 - 10400 Identifying Devices
 - 10605 Metal Lockers And Benches
 - 10520 Fire Protection Speciales
 - 10675 Metal Storage Shelving And Cabinets
 - 11450 Residential Appliances
 - 12354 Laboratory Casework And Equipment
 - 12364 Musical Equipment Storage
 - 12710 Auditorium Seating
 - 12760 Telescoping Gymnasium Seating
 - ALL UPPER AND LOWER CABINETS TO HAVE ROUNDED CORNERS.
 - ALL INTERIOR FINISHES SHALL COMPLY WITH THE REQUIRED CLASSIFICATIONS AS DESCRIBED IN THE FLORIDA FIRE PREVENTION CODE. ALL INTERIOR FINISHES TO BE CLASS "A".
 - PROVIDE ALL NECESSARY BLOCKING AND BACKING AT PARTITIONS ALONG ALL CABINET AREAS AS REQUIRED TO SUSTAIN 75LBS PER LINEAR FEET OF SHELVING/CASEWORK AS PER AMI STANDARDS. SEE SPECIFICATIONS.

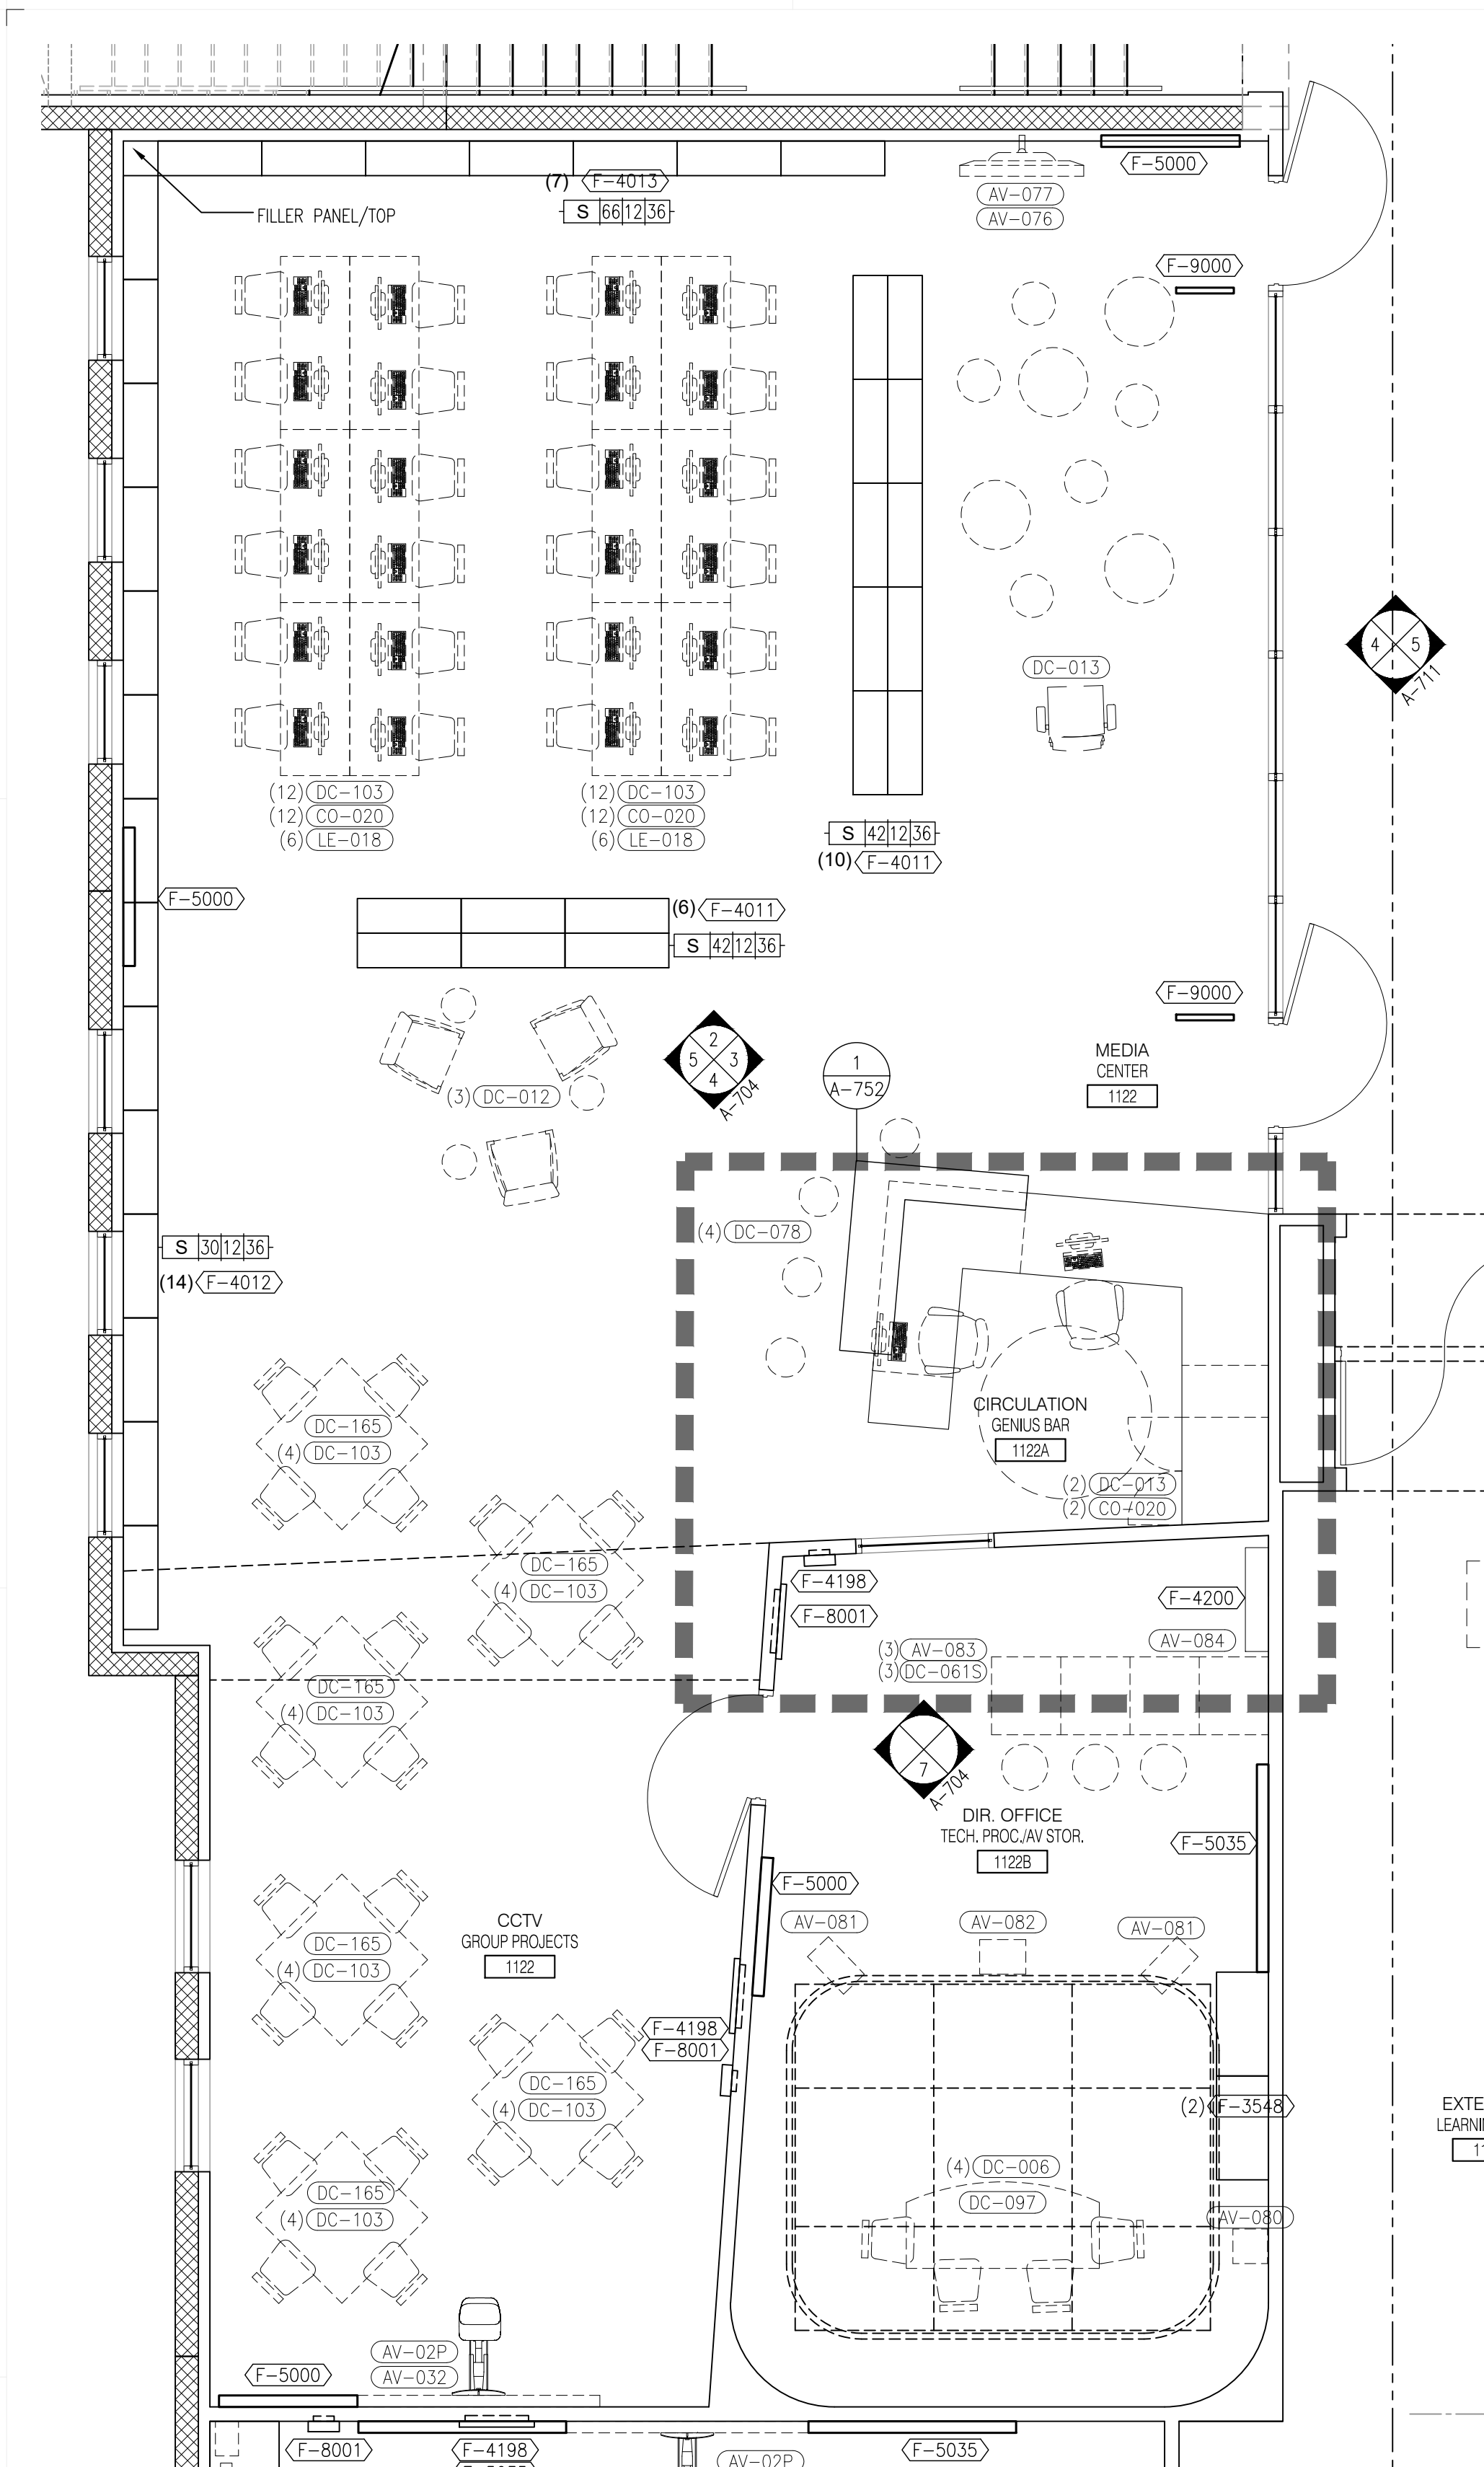


1 ENLARGED FIRST FLOOR MEDIA CENTER
A-704 Scale: 1/4"= 1'-0"

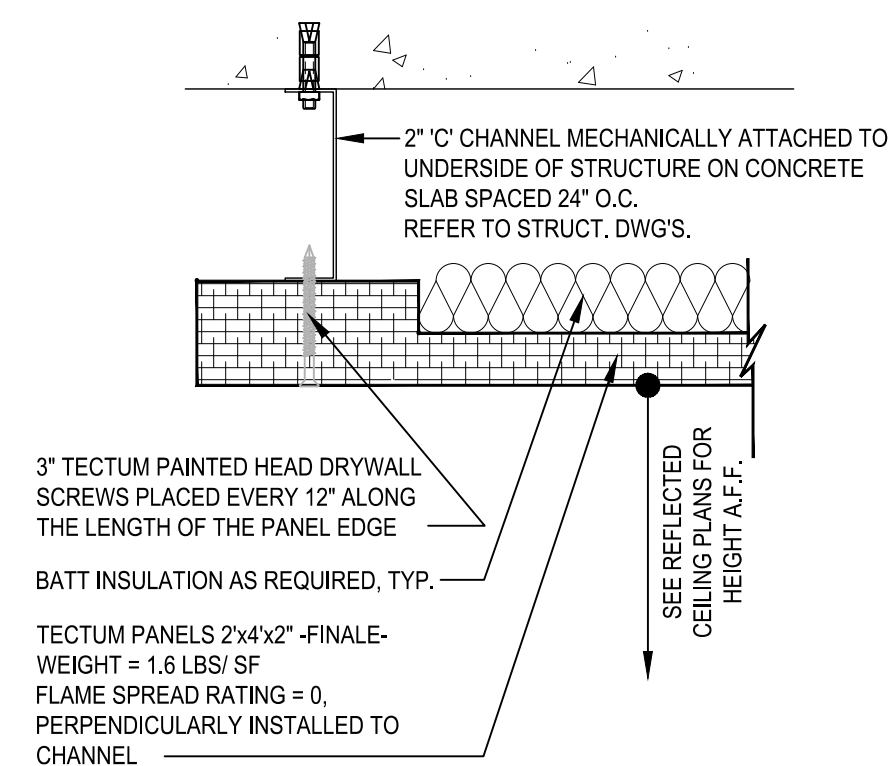


6 'TECTUM' PANEL DETAIL
A-704 Scale: 1/4"= 1'-0"

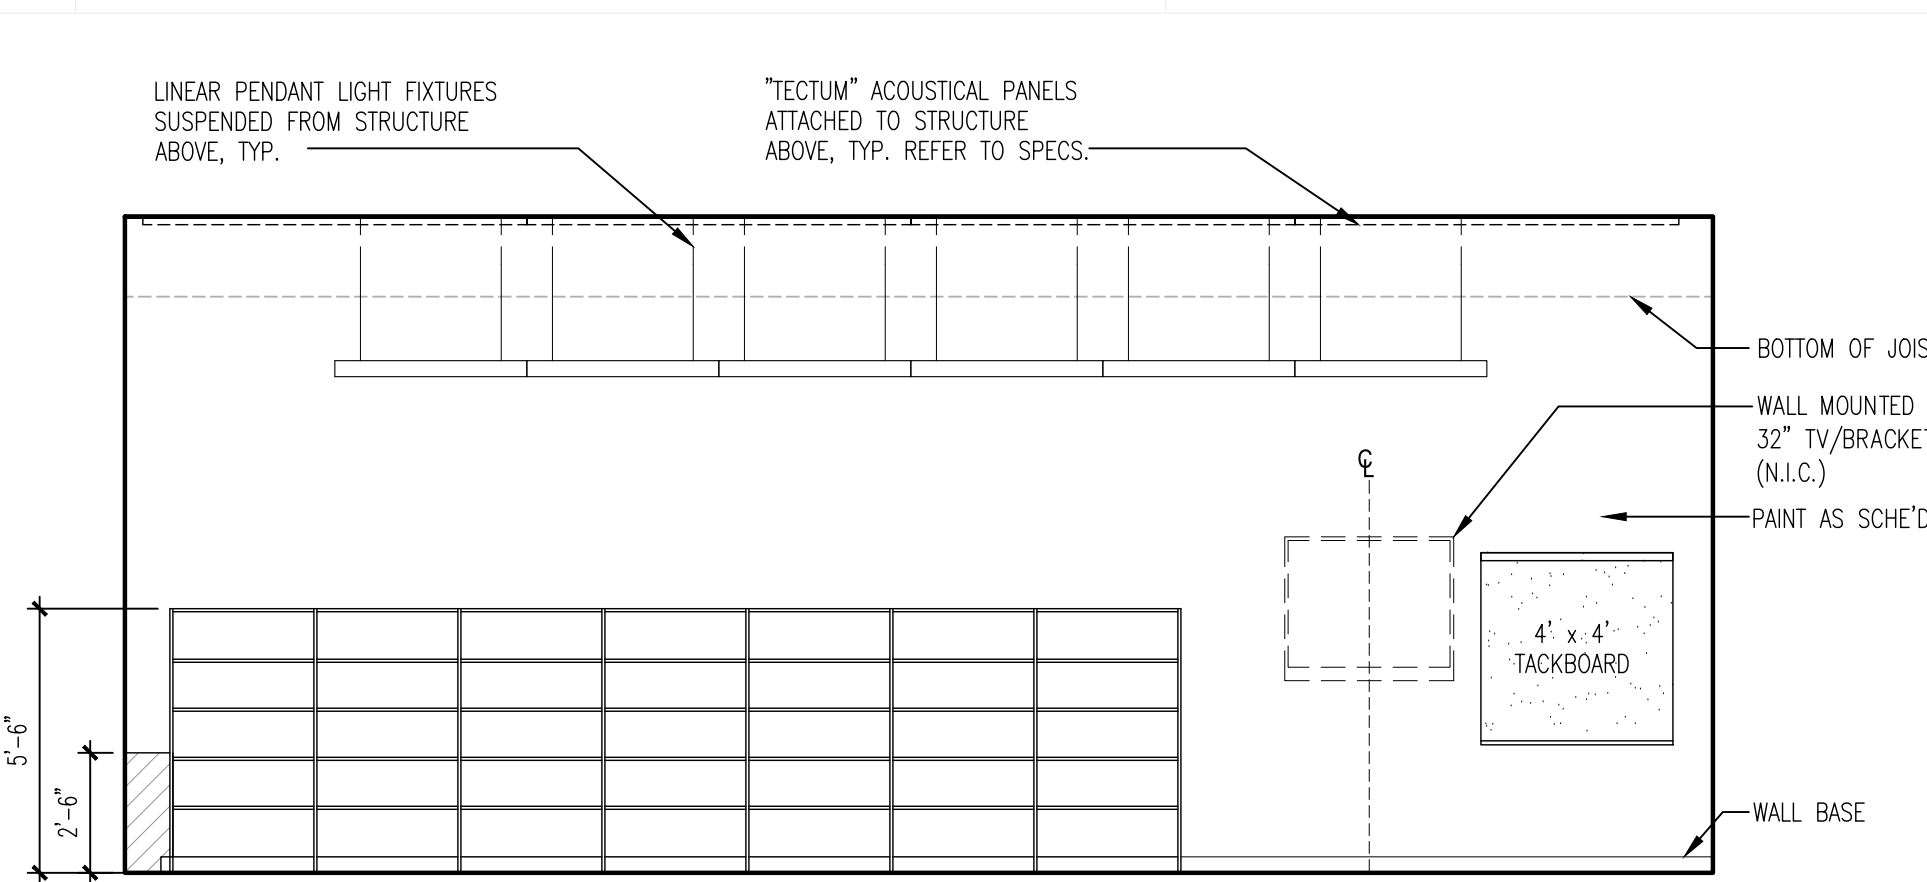

2 ENLARGED FIRST FLOOR MEDIA CENTER
A-704 Scale: 1/4"= 1'-0"

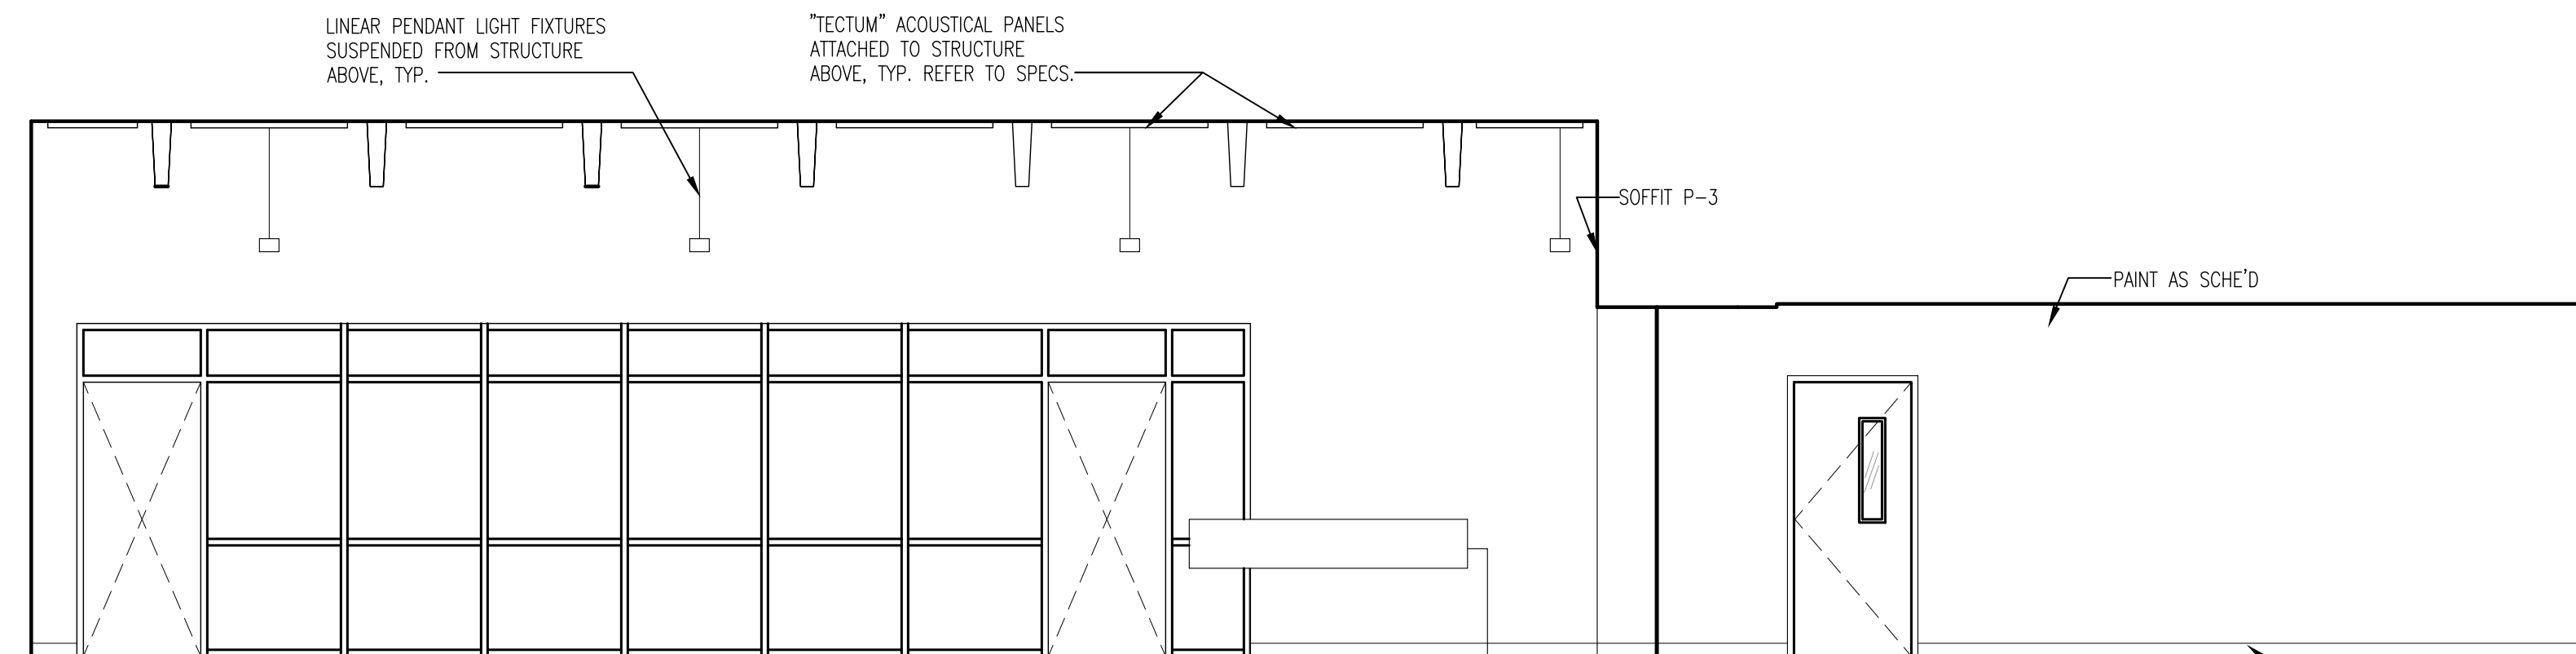


3 ENLARGED FIRST FLOOR MEDIA CENTER
A-704 Scale: 1/4"= 1'-0"

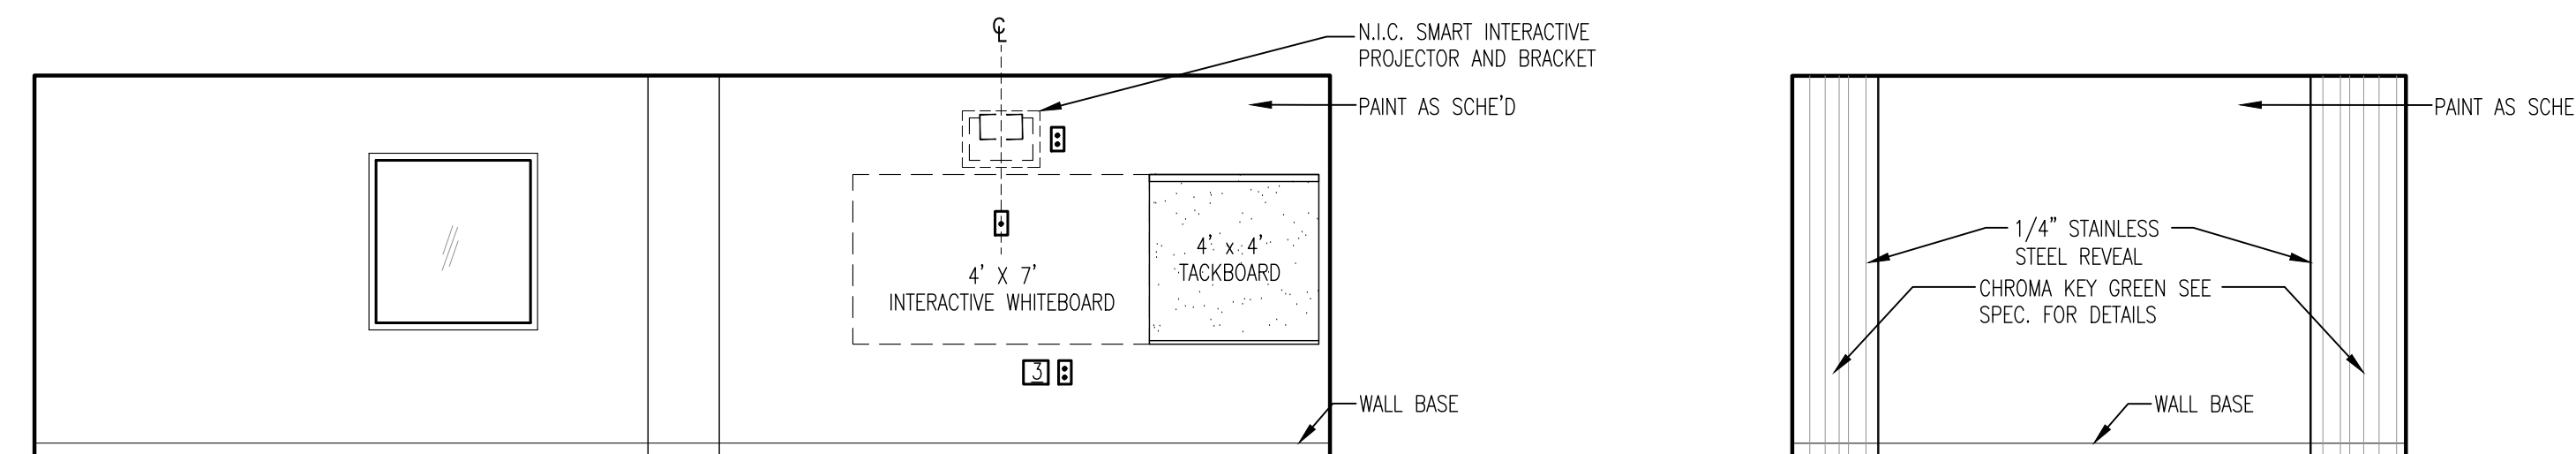

4 ENLARGED FIRST FLOOR MEDIA CENTER
A-704 Scale: 1/4"= 1'-0"

7 ENLARGED FIRST FLOOR MEDIA CENTER
A-704 Scale: 1/4"= 1'-0"

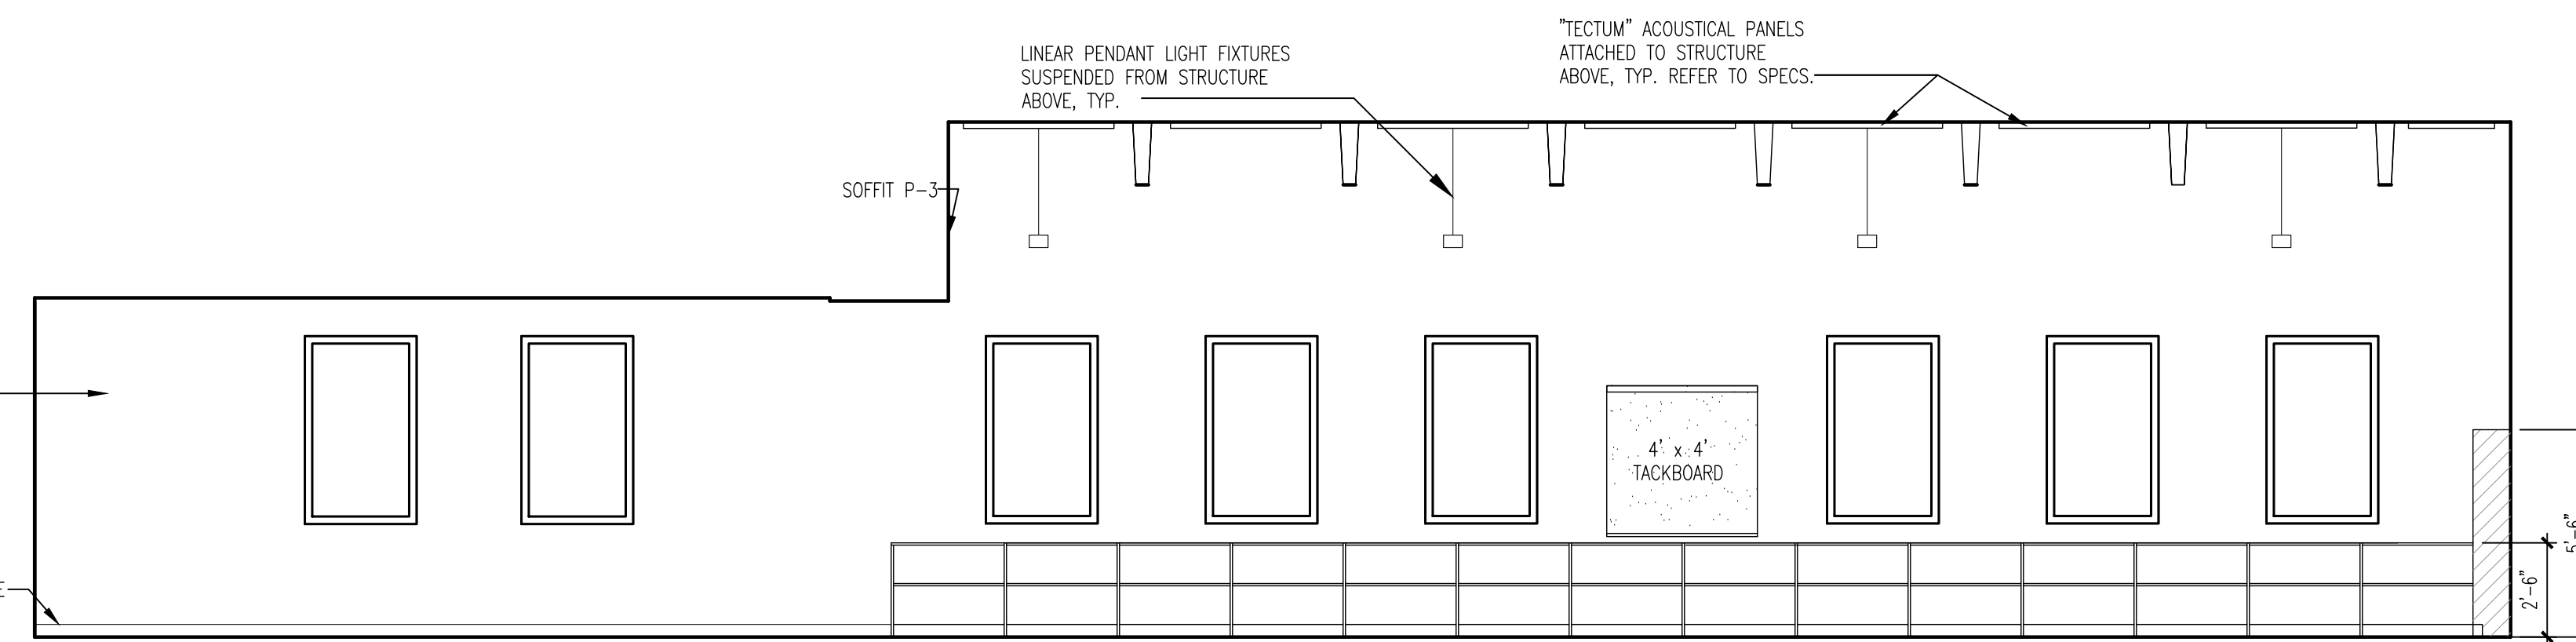

5 ENLARGED FIRST FLOOR MEDIA CENTER
A-704 Scale: 1/4"= 1'-0"

FURNITURE, FIXTURES & EQUIPMENT SCHEDULES


IN CONTRACT ITEMS (IC)						
NO.	DESCRIPTION	MANU/MODEL	SIZE	ELECT	PLUMB	GAS
F-3548	HEAVY DUTY ADJUSTABLE SHELVING		36" x 18" x 84" H			
F-4001	TV HUB		36" W x 8" D x 36" H	X		
F-4003	CEILING MOUNTED PROJECTOR BRACKET			X		
F-4008	FIRE SAFETY BLANKET	LARSEN NO. FB 68-6 SERIES	68" H x 8-1/4" W x 4" D			
F-4011	LIBRARY SHELVING		36" W x 12" D x 42" H			
F-4012	LIBRARY SHELVING		36" W x 12" D x 30" H			
F-4013	LIBRARY SHELVING		36" W x 12" D x 66" H			
F-4014	ADJUSTABLE LIBRARY SHELVING		36" x 18" x 84" H			
F-4200	TV HUB		36" W x 8" D x 36" H	X		
F-4035	MOTORIZED PROJECTOR SCREEN			X		
F-4036	OVERHEAD TRACK LIGHTING			X		
F-4198	CLOCK SPEAKER			X		
F-5000	TACKBOARD	CLARIDGE OR EQUAL	4'-0" x 4'-0"			
F-5035	COMBINATION TACKBOARD/MARKERBOARD	CLARIDGE OR EQUAL	6'-0" x 4'-0"			
F-5037	MARKERBOARD	CLARIDGE OR EQUAL	4'-0" x 4'-0"			
F-5066	COMBINATION TACKBOARD/MARKERBOARD	CLARIDGE OR EQUAL	8'-0" x 4'-0"			
F-8001	TEACHER CALL BOX			X		
F-9000	BOOK DETECTION SYSTEM	CHECKPOINT	SEE MANUFACTURER SPEC.	X		
MODEL: LIBERTY FX_MEDIA AREA						

NOT IN CONTRACT ITEMS (NIC) (XX-XXX)						
NO.	DESCRIPTION	MANU/MODEL	SIZE	ELECT	PLUMB	GAS
AV-076	TELEVISION AND BRACKET INSTALLATION	TROXELL INSTALLER		X		
AV-017	PROJECTION TABLE CART		24" x 18" x 34" H			
AV-02P	ACTIVEBOARD TOUCH	PROMETHEAN / ABMTS88JST	71" x 41"	X		
AV-021	CLASSROOM SOUND SYSTEM	ACHEVERA MDL#CAE-20MPAL	T.B.D.	X		
AV-022	TELEVISION EXTERNAL TUNER/ADAPTER	AVEVERA/ MTVBOXH11	T.B.D.	X		
AV-032	PROJECTION SYSTEM	NEC/ M311X	T.B.D.	X		
AV-074	TV UNIVERSAL 30"	TECHSTAR / 50L1350U		X		
AV-076	TV UNIVERSAL WALL MOUNT	PEPPERLESS/SA740P AND/OR STE650		X		
AV-077	TELEVISION 32" FLAT PANEL	SAMSUNG / MD32C		X		
AV-080	MIC BOX			X		
AV-081	CAMERA			X		
AV-082	PROMPTER			X		
AV-083	CONSOLE (3 STATIONS)			X		
AV-084	TV RACK		70" H x 24" W x 26" D			
CO-020	COMPUTER MAINSTREAM WITH MONITOR	T.B.D.		X		
CO-025	LASER PRINTER, BASIC NETWORK DUXLING	HP / P2055DN 070-1104	T.B.D.	X		
DC-004	CHAIR, DISCOVERY SERIES ERGONOMIC	ARTCO-BELL/ D10B	16"			
DC-006	CHAIR, DISCOVERY SERIES ERGONOMIC	ARTCO-BELL/ D10A	18"			
DC-008	CHAIR, EXECUTIVE HIGH BACK	HON - 2071BK	T.B.D.			
DC-009	CHAIR - PADDED SEAT	HON - H1081	T.B.D.			
DC-010	GUEST CHAIR	HON - 2304N	T.B.D.			
DC-012	LOUNGE CHAIR					
DC-013	TASK CHAIR, PNEUMATIC-BACK HEIGHT SWIVEL	HON - H7701.S				
DC-016	TEACHER'S SWIVEL CHAIR	SCHOLARSHIP/ SC110P	T.B.D.			
DC-019	CRENZIA		72" W x 24" D x 29-1/2" H			
DC-023	DESK - EXECUTIVE		72" W x 24" D x 29-1/2" H			
DC-024	DESK - SHAPE	HON OR EQUAL 105 SERIES	66" W x 30" D x 29" H			
DC-025	STUDENT DESK					
DC-026	DESK, PUPIL OPEN FRONT	VRCO/ 785MBB-MPL385	18" D x 24" W/ ADJ 22"-30" H			
DC-027	DESK, TEACHERS, SINGLE PEDESTAL	HON-H88251	48" W x 30" D			
DC-0408	TABLE-X BASE	HON - H8836.P	36" W x 36" D			
DC-0401	TABLE-SQUARE TOP	HON - H1036G	36" W x 36" D			
DC-042	TABLE-ART & PLANNING	SHAIN/SHOP-BILT #1300743705	60" W x 42" D x 36" H			
DC-043	TABLE-CLASSROOM	VRCO - 483060	30" W x 60" D x ADJ HEIGHT			
DC-046	TABLE - CONFERENCE	HON/DORAL - HTL4284	84" x 42" W/36" W AT END)x 29" H			
DC-048	TABLE - END	HON - H80193	24" x 20" W x 20" H			
DC-054	TABLE - STUDENT	VRCO				
DC-060	TABLE/BENCH - CONVERTIBLE	MIDWEST / T88-PT 012-KK01				
DC-0615	STOOL, TASK, ADJUSTABLE HGT	JC WHITE/HON H7705				
DC-078	WOOD STOOL	PRIDE #30				
DC-088	CHAIR EXECUTIVE MID BACK	HON	T.B.D.			
DC-097	BOW FRONT DESK SHELL	HON / H10596	72" W x 36" D x 29" H			
DC-103	CHAIR - WOOD W/RACK UNDER SEAT	JASPER CHAIR	18"			
DC-165	TABLE - LIBRARY STUDY TABLE	MARK PRODUCTS	42" W x 42" D x 29" H			
DC-177	TABLE - COMPUTER	VRCO #873060	24" W x 60" D x ADJ HEIGHT	X		
FA-009	COUCH, RECOVERY	WINCO / 855-03	24" W x 72" L x 22" H			
FS-011	MICROWAVE, 1.2 CU. FT	KENMORE # 20-69129	21-7/8" W x 12-1/2" H x 17-7/8" D	X		
FS-013	K2S WATER	KENMORE # 46-49599		X		
FS-027	VENDING MACHINE	FWE / PH-1826-18U	30-1/2" W x 33-1/4" D x 69" H			
LC-021	CABINET, STORAGE STEEL	HON - HSC1872L	36" W x 18" D x 72" H			
LC-048	SAFE - 90 MIN FIRE RATED	MUTUAL - GV-4520	51" H x 26" W x 29" D (1930 lbs)			
LE-004	BOOK TRUCK, 3 FLAT SHELVES	BRETFORD F336	24" x 28" x 42" H			
LE-005	BOOK TRUCK, 6 SLOPING SHELVES	BRETFORD V336	37" x 18" D x 42" H			
LE-006	BOOKCASE	HON - H105534	36" W x 13" D x 57-1/8" H			
LE-018	COMPUTER CARROL	INSTITUTIONAL PRODUCTS	60" W x 30" D x 36" H	X		
MM-009	SCREEN, 3-PANEL	WINCO / 02-50-3313	60" x 61"	X		
NIC-0001	TECHNOLOGY CENTER		T.B.D.			
NIC-1000	COMPUTER TABLE		30" x 24"	X		
NIC-4034	CEILING MOUNTED PROJECTOR		T.B.D.	X		
NIC-4035	AV SCREEN & BRACKET		161" x 10" H			
NIC-4000	AREA RUG		6' x 6'			
NIC-4001	KID OTTOMAN					
OF-002	FAX MACHINE	BROTHER BR72820		X		
OF-003	FILE CABINET	HON - H212C.P.	18-1/4" W x 28-1/2" D x 29" H			
OF-005	FILE CABINET VERTICAL 4-DRAWER LEGAL	HON - H214C.P.	18-1/4" W x 28-1/2" D x 52" H			
OF-006	FILE CABINET LATERAL 2-DRAWER	HON - H882.L	18" D x 36" W x 28" H			
OF-007	FILE CABINET LATERAL 5-DRAWER	HON - H885.L	36" W x 19-1/4" D x 64" H			
OF-018	SHREDDER WITH BASKET	GBC / 85X	14" W x 12" D x 18" H	X		


NOTES:
1. NOT IN CONTRACT NUMERICAL SEQUENCE REFLECT MIAMI DADE COUNTY PUBLIC SCHOOLS PRELIMINARY FF&E LIST DATED 1/20/2014.
2. COORDINATE ALL N.I.C. FF&E WITH MDCPS FOR FINAL LOCATIONS AND SELECTIONS

LEGEND		MOUNTING HEIGHTS FOR INSTRUCTIONAL BOARDS	
IN-CONTRACT F.F.E.			
F-1000	TABLES	PRE-K-3RD	1'-4" AFF OVERALL 5' BOARD HGT
F-2000	WALL & BASE CABINERY	PRE-K-3RD	2'-4" AFF OVERALL 4' BOARD HGT
F-3000	SHELVING	4th GRADE	2'-8" AFF OVERALL 4' BOARD HGT
F-3500	METAL SHELVING	MIDDLE	2'-9" AFF OVERALL 4' BOARD HGT
F-4000	EQUIPMENT	STAFF	3'-0" AFF OVERALL 4' BOARD HGT
F-5000	INSTRUCTIONAL AIDS		
F-6000	CHAIRS		
F-7000	SCIENCE EQUIPMENT		
F-8000	COM EQUIPMENT		
F-9000	SITE EQUIPMENT		
IN-CONTRACT CASEWORK		TYPE OR STYLE refer to DWGS, A-222 for details	
B	BASE	O	OPEN
C	CABINET	P	PANEL
D	DRAWERS	Q	COMBINATION LOWER/UPPER
E	VENTED	R	COUNTER
F	FULL LENGTH-WALL-WALL	S	SLIDING-SHELVES
I	DISH CABINET/LINENS	T	TABLE
K	DESK	U	UPPER
L	SPECIAL OR CUSTOM	V	VERTICAL DIVIDERS
M	WALLBOXES	W	WALL
N	FALSE PANEL		


- GENERAL NOTES**
- FOR TOILET ROOMS, REFER TO DRAWINGS A-712 & A-713 FOR ENLARGED PLANS AND ELEVATIONS.
 - FOR TOILET ROOM PROGRAM SPACE ACCESSORIES AND FOR GENERAL MOUNTING HEIGHTS, REFER TO SHEETS A-700.
 - FOR CASEWORK, ELEVATIONS AND DETAILS, REFER TO DRAWINGS A-750 & A-751.
 - REFER TO THE FOLLOWING SPECIFICATION SECTIONS FOR MANUFACTURERS AND MODEL NUMBERS NOT SHOWN ABOVE:
 - 10100 Visual Display Board And Display Cases (including tackboards)
 - 10101 Tackable Wall System
 - 10105 Plastic Toilet Partitions And Shower Screens
 - 10190 Cubicle Curtain Track
 - 10400 Identifying Devices
 - 10605 Metal Lockers And Benches
 - 10520 Fire Protection Speculies
 - 10675 Metal Storage Shelving And Cabinets
 - 11450 Residential Appliances
 - 12354 Laboratory Casework And Equipment
 - 12364 Musical Equipment Storage
 - 12710 Auditorium Seating
 - 12760 Telescoping Gymnasium Seating
 - ALL UPPER AND LOWER CABINETS TO HAVE ROUNDED CORNERS.
 - ALL INTERIOR FINISHES SHALL COMPLY WITH THE REQUIRED CLASSIFICATIONS AS DESCRIBED IN THE FLORIDA FIRE PREVENTION CODE. ALL INTERIOR FINISHES TO BE CLASS "A".
 - PROVIDE ALL NECESSARY BLOCKING AND BACKING AT PARTITIONS ALONG ALL CABINET AREAS AS REQUIRED TO SUSTAIN 75LBS PER LINEAR FEET OF SHELVING/CASEWORK AS PER ANI STANDARDS. SEE SPECIFICATIONS.

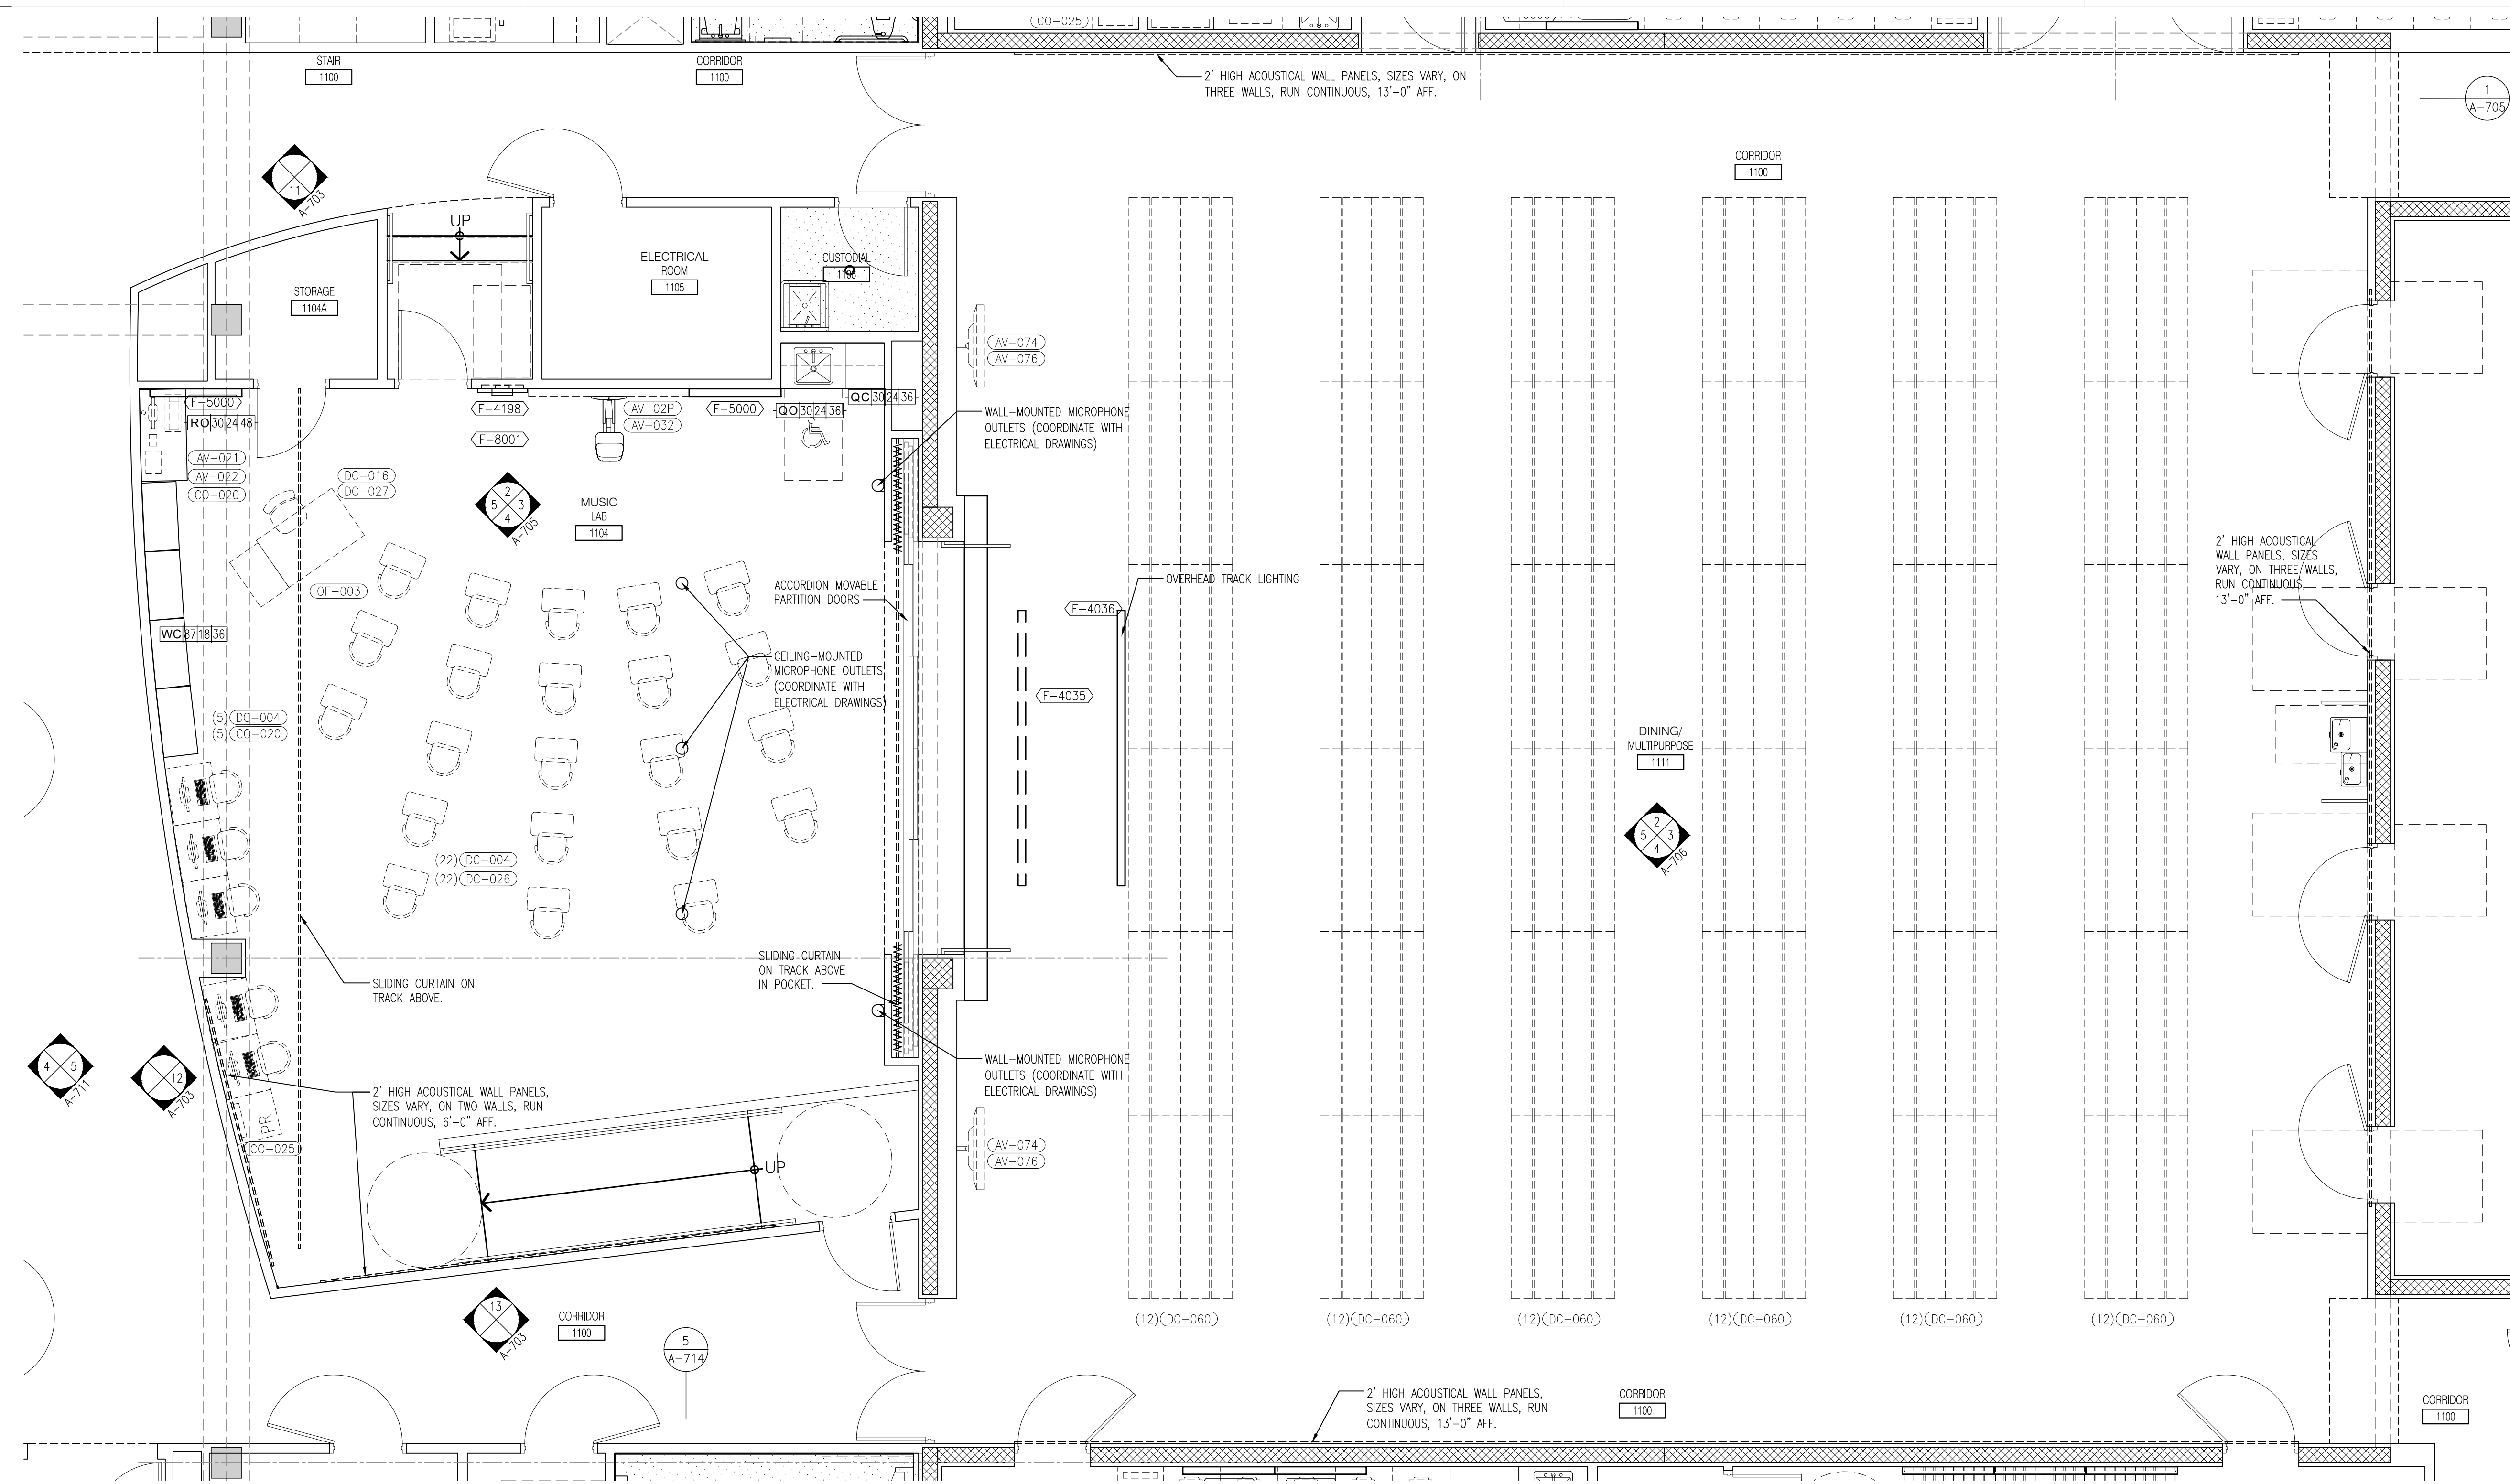


1 ENLARGED FIRST FLOOR MUSIC CLASSROOM
A-705 Scale: 1/4"= 1'-0"

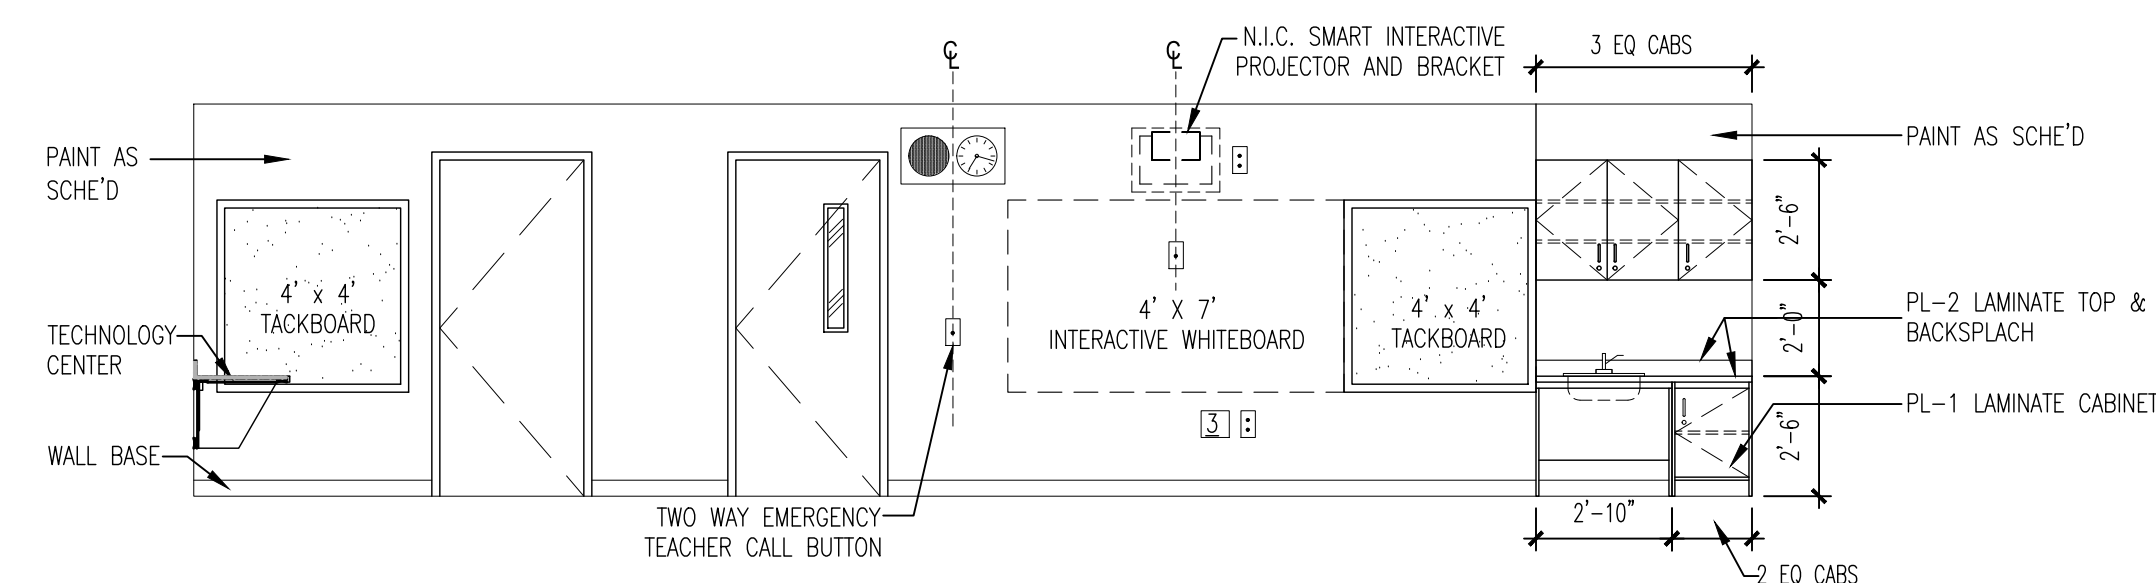


2 ENLARGED FIRST FLOOR MUSIC CLASSROOM
A-705 Scale: 1/4"= 1'-0"

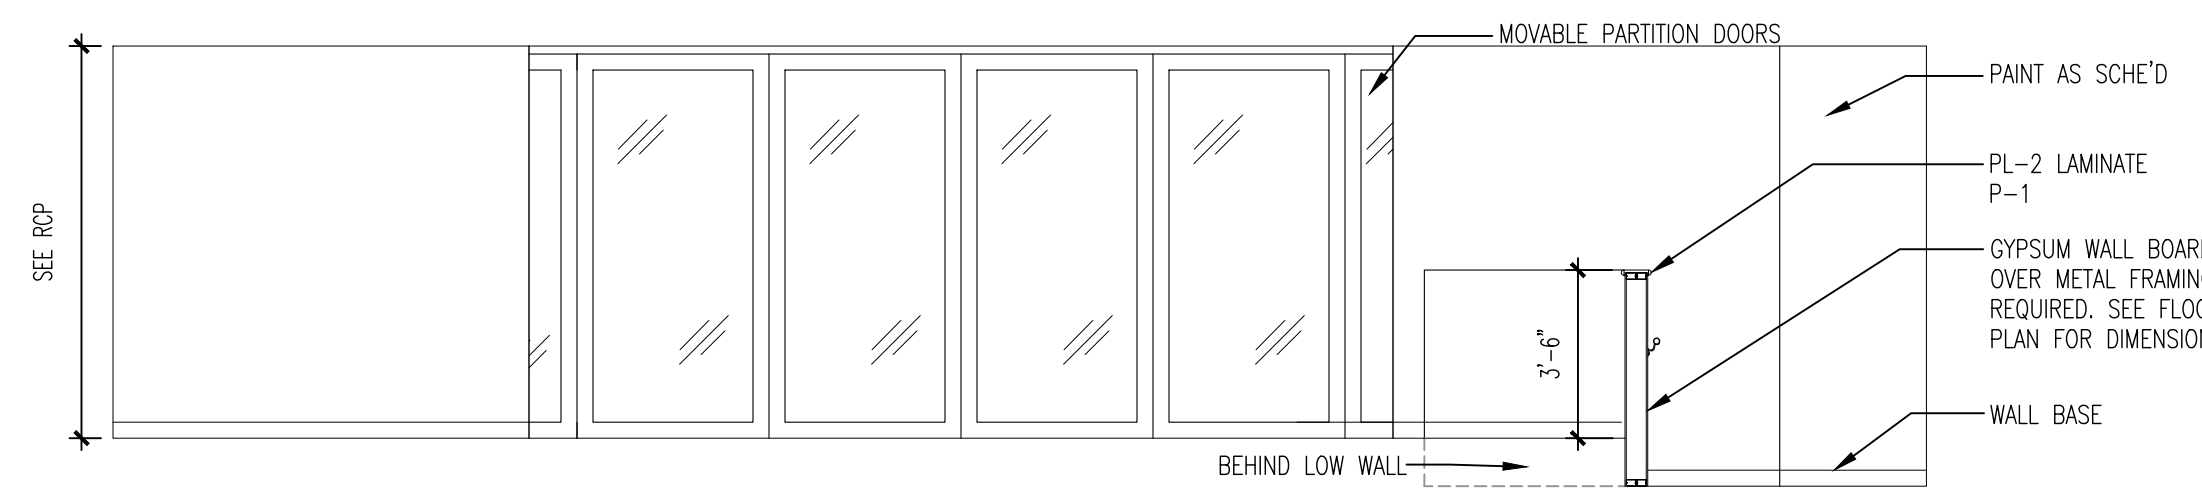

3 ENLARGED FIRST FLOOR MUSIC CLASSROOM
A-705 Scale: 1/4"= 1'-0"

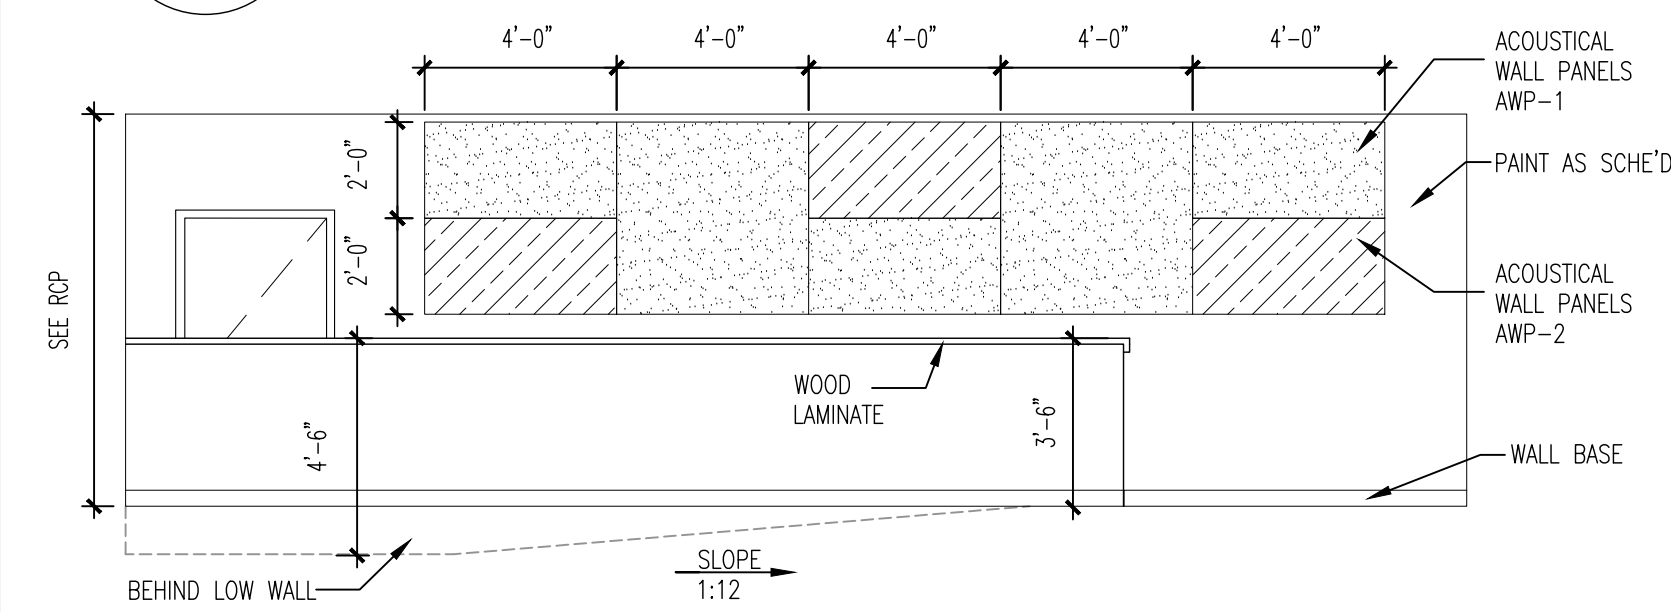

4 ENLARGED FIRST FLOOR MUSIC CLASSROOM
A-705 Scale: 1/4"= 1'-0"

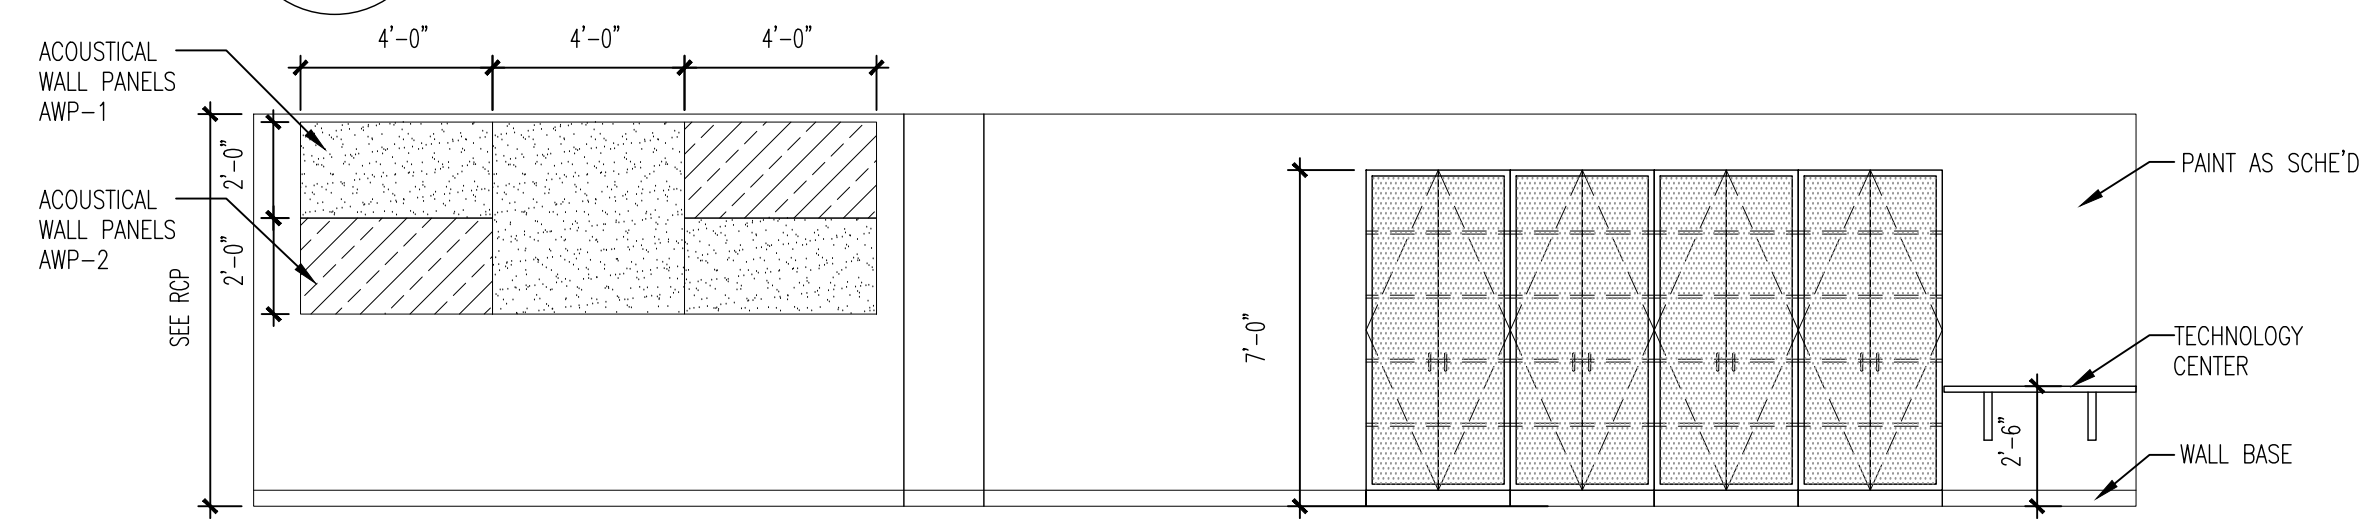

5 ENLARGED FIRST FLOOR MUSIC CLASSROOM
A-705 Scale: 1/4"= 1'-0"

FURNITURE, FIXTURES & EQUIPMENT SCHEDULES


IN CONTRACT ITEMS (IC) F-XXXX						
NO.	DESCRIPTION	MANU./MODEL	SIZE	ELECT	PLUMB	GAS
F-3548	HEAVY DUTY ADJUSTABLE SHELVING		36" x 18" x 84"H			
F-4001	TV HUB		36" W x 8" D x 36" H	X		
F-4003	CEILING MOUNTED PROJECTOR BRACKET			X		
F-4008	FIRE SAFETY BLANKET	LARSEN NO. FB 68-E SERIES	68" W x 8-1/4" W x 4' D			
F-4011	LIBRARY SHELVING		36" W x 12" D x 42" H			
F-4012	LIBRARY SHELVING		36" W x 12" D x 30" H			
F-4013	LIBRARY SHELVING		36" W x 12" D x 66" H			
F-4014	ADJUSTABLE LIBRARY SHELVING		36" W x 18" D x 84" H			
F-4200	TV HUB		36" W x 8" D x 36" H	X		
F-4035	MOTORIZED PROJECTOR SCREEN			X		
F-4036	OVERHEAD TRACK LIGHTING			X		
F-4198	CLOCK SPEAKER			X		
F-5000	TACKBOARD	CLARIDGE OR EQUAL	4'-0" x 4'-0"			W/MARKER TRAY AND MAP RAIL
F-5035	COMBINATION TACKBOARD/MARKERBOARD	CLARIDGE OR EQUAL	6'-0" x 4'-0"			
F-5037	MARKERBOARD	CLARIDGE OR EQUAL	4'-0" x 4'-0"			
F-5066	COMBINATION TACKBOARD/MARKERBOARD	CLARIDGE OR EQUAL	8'-0" x 4'-0"			
F-8001	TEACHER CALL BOX			X		
F-9000	BOOK DETECTION SYSTEM	CHECKPOINT	SEE MANUFACTURER SPEC.	X		MODEL: LIBERTY FX_MEDIA AREA

NOT IN CONTRACT ITEMS (NIC) XX-XXXX						
NO.	DESCRIPTION	MANU./MODEL	SIZE	ELECT	PLUMB	GAS
AV-676	TELEVISION AND BRACKET INSTALLATION	TROXELL INSTALLER		X		
AV-677	PROJECTION TABLE CART	PROMETHEAN / ARMTSTBUST	24" x 18" x 34" H			
AV-678	ACTIVBOARD TOUCH	PROMETHEAN / ARMTSTBUST	71" x 41" H	X		
AV-679	CLASSROOM SOUND SYSTEM	ACHEVER MDL#CAE-20WPA	T.B.D.	X		
AV-680	TELEVISION EXTERNAL TUNER/ADAPTER	ACHEVER MDL#CAE-20WPA	T.B.D.	X		
AV-681	PROJECTION SYSTEM	NEC / M311X	T.B.D.	X		
AV-682	TV UNIVERSAL WALL MOUNT	TOUCHSCREEN / 5013350U		X		
AV-683	TV UNIVERSAL WALL MOUNT	PEPPERLESS/SA740P AND/OR ST650		X		
AV-684	TELEVISION 32" FLAT PANEL	SAMSUNG / MD32C		X		
AV-685	MIC BOX			X		
AV-686	CAMERA			X		
AV-687	PROMPTER			X		
AV-688	CONSOLE (3 STATIONS)			X		
AV-689	TV RACK	70" H x 24" W x 26" D	T.B.D.	X		
CO-020	COMPUTER MAINSTREAM WITH MONITOR	T.B.D.		X		
CO-025	LASER PRINTER, BASIC NETWORK DUPLEXING	HP / P2055DN 070-1104	T.B.D.	X		
DC-004	CHAIR, DISCOVERY SERIES ERGONOMIC	ARTCO-BELL/ D10A	16"			SEAT AND LEG T.B.D.
DC-006	CHAIR, DISCOVERY SERIES ERGONOMIC	ARTCO-BELL/ D10A	18"			SEAT AND LEG T.B.D.
DC-008	CHAIR EXECUTIVE HIGH BACK	HON / 2071BK	T.B.D.			
DC-009	CHAIR - PADDED SEAT	HON - H1081	T.B.D.			
DC-010	GUEST CHAIR	HON - 2304N	T.B.D.			
DC-012	LOUNGE CHAIR					
DC-013	TASK CHAIR PNEUMATIC-BACK HEIGHT SWIVEL	HON - H7701.S				
DC-016	TEACHER'S SWIVEL CHAIR	SCHOLARSHIP/ SC110P	T.B.D.			
DC-019	CREDENZA		72" W x 24" D x 29-1/2" H			
DC-023	DESK - EXECUTIVE		72" W x 24" D x 29-1/2" H			
DC-024	DESK L-SHAPE	HON OR EQUAL 105 SERIES	66" W x 30" D x 29" H			
DC-025	STUDENT DESK					
DC-026	DESK, PUPIL OPEN FRONT	VRCO/ 785MBB-MPL385	18" D x 24" W/ ADJ 22"-30" H			BLACK, FUSION, MAPLE TOP
DC-027	DESK, TEACHERS, SINGLE PEDESTAL	HON-H88251	48" W x 30" D			TAN METAL W/OAK LAMINATE TOP
DC-0408	TABLE-X BASE	HON - H8836.P				
DC-0401	TABLE-SQUARE TOP	HON - H1036G	36" W x 36" D			
DC-042	TABLE-ART & PLANNING	SHAIN/SHOP-BLT #1300743705	60" W x 42" D x 36" H			
DC-043	TABLE-CLASSROOM	VRCO - 483060	30" W x 60" D x ADJ HEIGHT			BIRCH/MAPLE TOP
DC-046	TABLE - CONFERENCE	HON/DGBAL - HTL4284	84" x 42" W/36" W AT ENDS x 29" H			BIRCH/MAPLE TOP
DC-048	TABLE - END	HON - H80193	24" x 20" W x 20" H			BIRCH/MAPLE TOP
DC-054	TABLE - STUDENT	VRCO				
DC-060	TABLE/BENCH - CONVERTIBLE	MIDWEST / T88-PT 012-KK01				DINING/MULTIPURPOSE
DC-0615	STOOL, TASK, ADJUSTABLE HGT	JC WHITE/HON H7705				
DC-078	WOOD STOOL	PRIDE #30				
DC-088	CHAIR EXECUTIVE MID BACK	HON	T.B.D.			CONFERENCE ROOM
DC-097	BOW FRONT DESK SHELL	HON / H10596	72" W x 36" D x 29" H			
DC-103	CHAIR - WOOD W/RACK UNDER SEAT	JASPER CHAIR	18"			
DC-165	TABLE - LIBRARY STUDY TABLE	MARK PRODUCTS	42" W x 42" D x 29" H			
DC-177	TABLE - COMPUTER	VRCO #873060	24" W x 60" D x ADJ HEIGHT	X		
FA-009	COUCH, RECOVERY	WINCO / 855-03	24" W x 72" D x 22" H			CLINIC
FS-011	MICROWAVE, 1.2 CU. FT	KENMORE # 20-69129	21-7/8" W x 12-1/2" H x 17-7/8" D	X		
FS-013	K2 WATER	KENMORE # 44-49599		X		
FS-027	VENDING MACHINE	FWE / PH-1826-18U	30-1/2" W x 33-1/4" D x 69" H			
LC-021	CABINET, STORAGE STEEL	HON - HSC1872L	36" W x 18" D x 72" H			
LC-048	SAFE - 90 MIN FIRE RATED	MUTUAL - GV-4520	51" H x 26" W x 29" D (1930 lbs)			THICK SHELVES
LE-004	BOOK TRUCK, 3 FLAT SHELVES	BREITFORD F336	24" x 28" D x 42" H			
LE-005	BOOK TRUCK, 6 SLIDING SHELVES	BREITFORD V336	37" x 18" D x 42" H			
LE-006	BOOKCASE	HON - H105534	36" W x 13" D x 57-1/8" H			
LE-018	COMPUTER CARROL	INSTITUTIONAL PRODUCTS	60" W x 30" D x 36" H	X		
MM-009	SCOREN, 3-PANEL	WINCO / 02-50-3313	60" x 81" x 6"	X		CLINIC
NIC-0001	TECHNOLOGY CENTER		T.B.D.	X		
NIC-1000	COMPUTER TABLE		30" x 24"	X		
NIC-4034	CEILING MOUNTED PROJECTOR	T.B.D.		X		
NIC-4035	AV SCREEN & BRACKET	T.B.D.	16" x 10" H			
NIC-4000	AREA RUG		6' x 6'			
NIC-4001	KID OTTOMAN	BROTHER BR7820		X		
OF-002	FAX MACHINE					
OF-003	FILE CABINET	HON - H212C.P	18-1/4" W x 28-1/2" D x 29" H			
OF-005	FILE CABINET VERTICAL 4-DRAWER LEGAL	HON - H214C.P	18-1/4" W x 28-1/2" D x 52" H			
OF-006	FILE CABINET LATERAL 2-DRAWER	HON - H882.L	18" D x 36" W x 28" H			
OF-007	FILE CABINET LATERAL 5-DRAWER	HON - H885.L	36" W x 19-1/4" D x 64" H			
OF-016	SHREDDER WITH BASKET	GBC / 85X	14" W x 12" D x 18" H	X		


NOTES:
1. NOT IN CONTRACT NUMERICAL SEQUENCE REFLECT MIAMI DADE COUNTY PUBLIC SCHOOLS PRELIMINARY FF&E LIST DATED 1/20/2014.
2. COORDINATE ALL N.I.C. FF&E WITH MDGPS FOR FINAL LOCATIONS AND SELECTIONS

LEGEND		MOUNTING HEIGHTS FOR INSTRUCTIONAL BOARDS	
IN-CONTRACT F.F.E.			
F-1000	TABLES	PRE-K-3RD	1'-4" AFF OVERALL 5' BOARD HGT
F-2000	WALL & BASE CABINETS	PRE-K-3RD	2'-4" AFF OVERALL 4' BOARD HGT
F-3000	SHELVING	4th GRADE	2'-8" AFF OVERALL 4' BOARD HGT
F-3500	METAL SHELVING	MIDDLE	2'-9" AFF OVERALL 4' BOARD HGT
F-4000	EQUIPMENT	STAFF	3'-0" AFF OVERALL 4' BOARD HGT
F-5000	INSTRUCTIONAL AIDS		
F-6000	CHAIRS		
F-7000	SCIENCE EQUIPMENT		
F-8000	COM EQUIPMENT		
F-9000	SITE EQUIPMENT		
IN-CONTRACT CASEWORK		TYPE OR STYLE refer to DWGS, A-222 for details	
B	BASE	O	OPEN
C	CABINET	P	PANEL
D	DRAWERS	Q	COMBINATION LOWER/UPPER
E	VENTED	R	COUNTER
F	FULL LENGTH-WALL-WALL	S	SLIDING-SHELVES
G	DISH CABINET/LINENS	T	TABLE
H	SPECIAL OR CUSTOM	U	UPPER
I	WALLBOARDS	V	VERTICAL DIVIDERS
N	FALSE PANEL	W	WALL


- GENERAL NOTES**
- FOR TOILET ROOM, REFER TO DRAWINGS A-712 & A-713 FOR ENLARGED PLANS AND ELEVATIONS.
 - FOR TOILET ROOM PROGRAM SPACE ACCESSORIES AND FOR GENERAL MOUNTING HEIGHTS, REFER TO SHEETS A-700.
 - FOR CASEWORK, ELEVATIONS AND DETAILS, REFER TO DRAWINGS A-750 & A-751.
 - REFER TO THE FOLLOWING SPECIFICATION SECTIONS FOR MANUFACTURERS AND MODEL NUMBERS NOT SHOWN ABOVE:
 - 10100 Visual Display Board And Display Cases (including tackboards)
 - 10125 Tackable Wall System
 - 10165 Plastic Toilet Partitions And Shower Screens
 - 10190 Cubicle Curtain Track
 - 10400 Identifying Devices
 - 10505 Metal Lockers And Benches
 - 10520 Fire Protection Speculies
 - 10675 Metal Storage Shelving And Cabinets
 - 11450 Residential Appliances
 - 12354 Laboratory Casework And Equipment
 - 12364 Musical Equipment Storage
 - 12710 Auditorium Seating
 - 12760 Telescoping Gymnasium Seating
 - ALL UPPER AND LOWER CABINETS TO HAVE ROUNDED CORNERS.
 - ALL INTERIOR FINISHES SHALL COMPLY WITH THE REQUIRED CLASSIFICATIONS AS DESCRIBED IN THE FLORIDA FIRE PREVENTION CODE. ALL INTERIOR FINISHES TO BE CLASS "A".
 - PROVIDE ALL NECESSARY BLOCKING AND BACKING AT PARTITIONS ALONG ALL CABINET AREAS AS REQUIRED TO SUSTAIN 75LBS PER LINEAR FEET OF SHELVING/CASEWORK AS PER AMI STANDARDS. SEE SPECIFICATIONS.

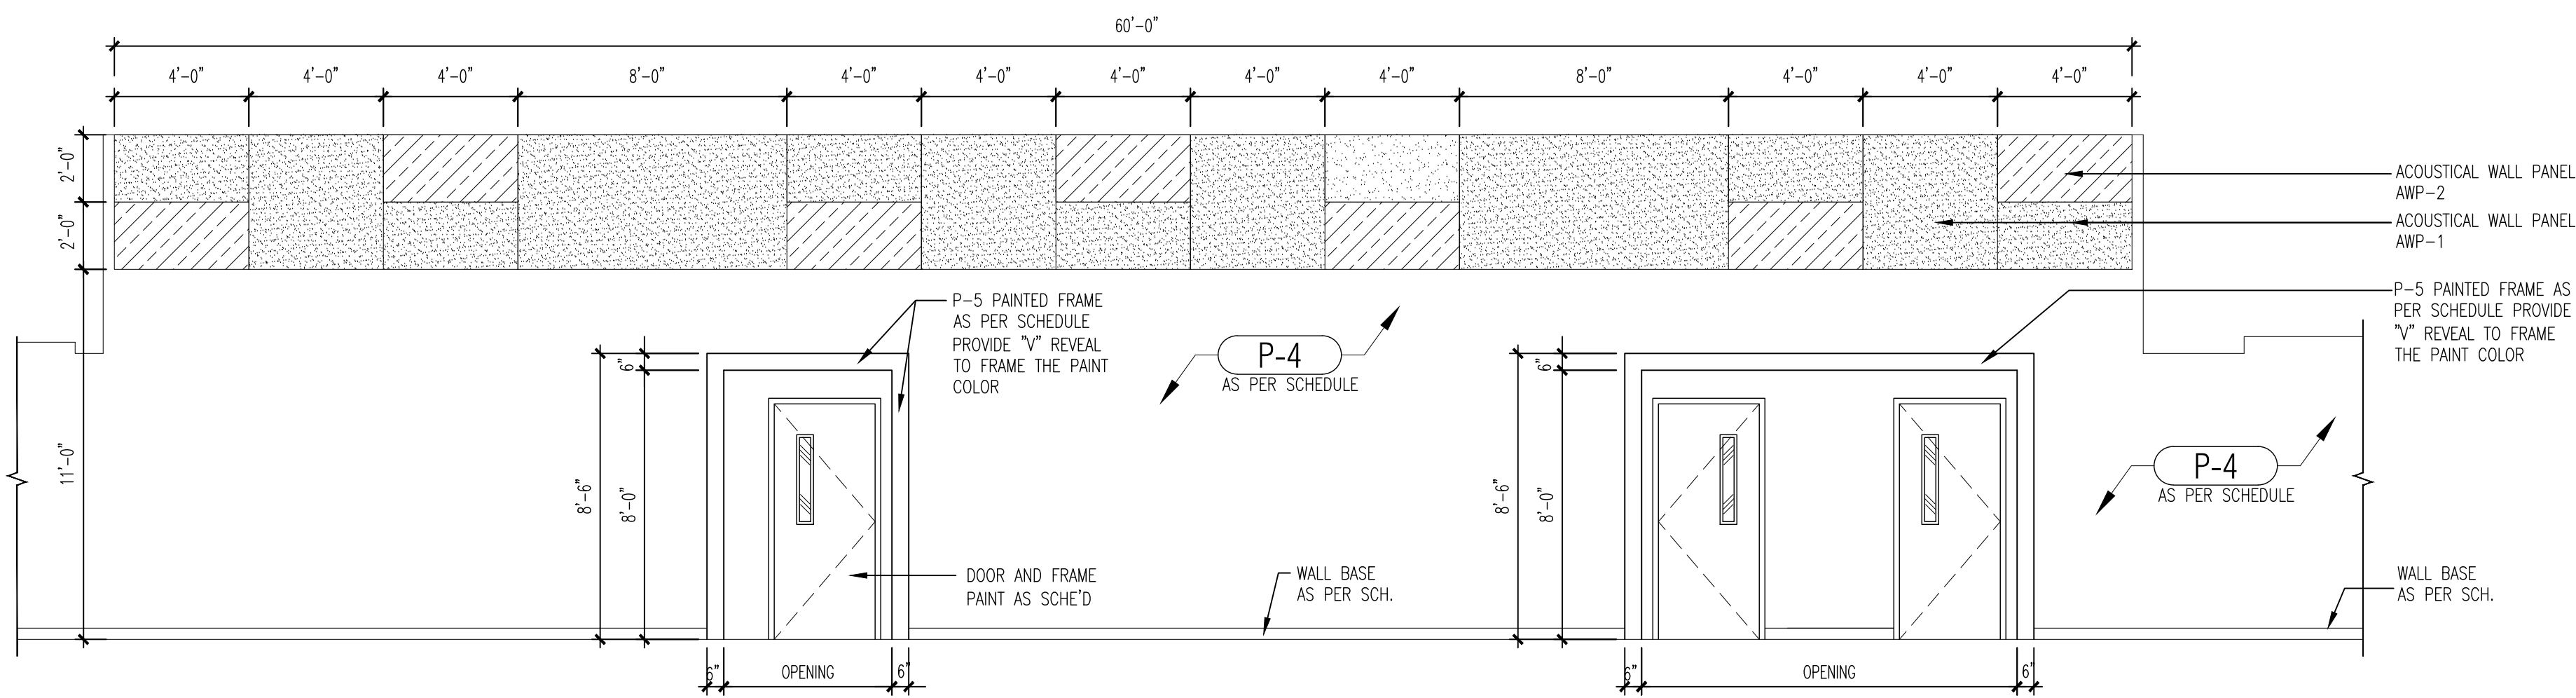


2 DINING ELEVATION
A-706 Scale: 1/4" = 1'-0"

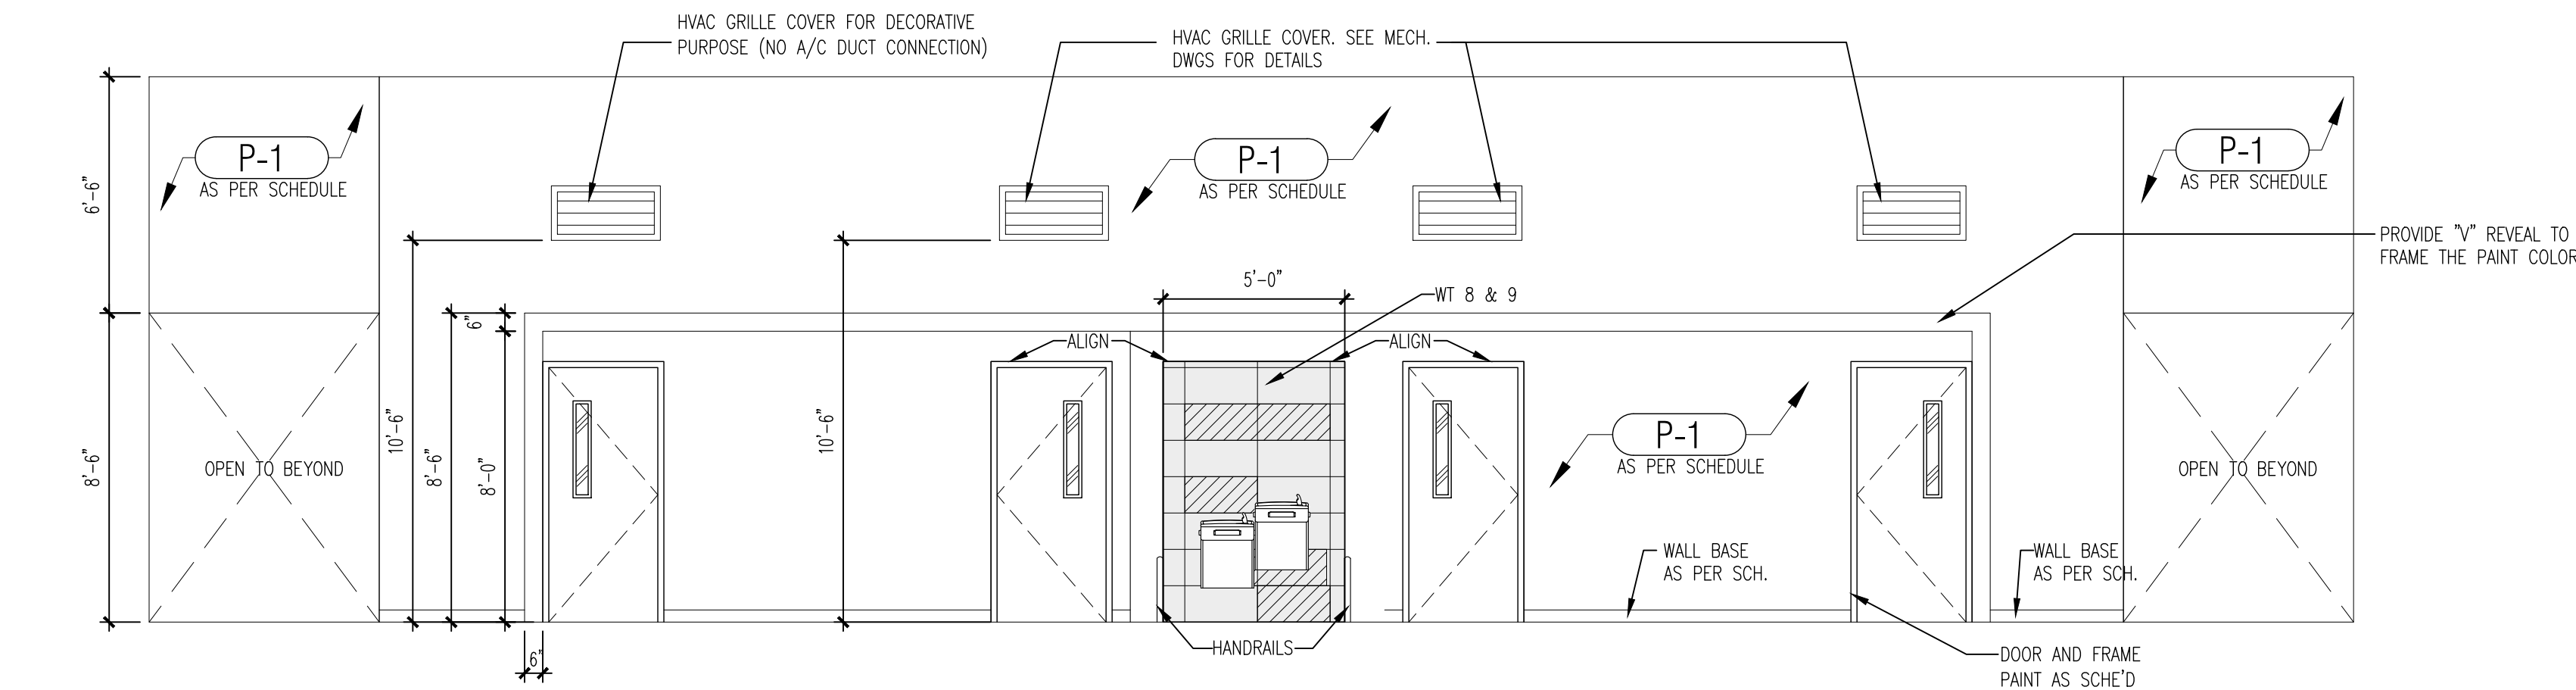

3 DINING ELEVATION
A-706 Scale: 1/4" = 1'-0"

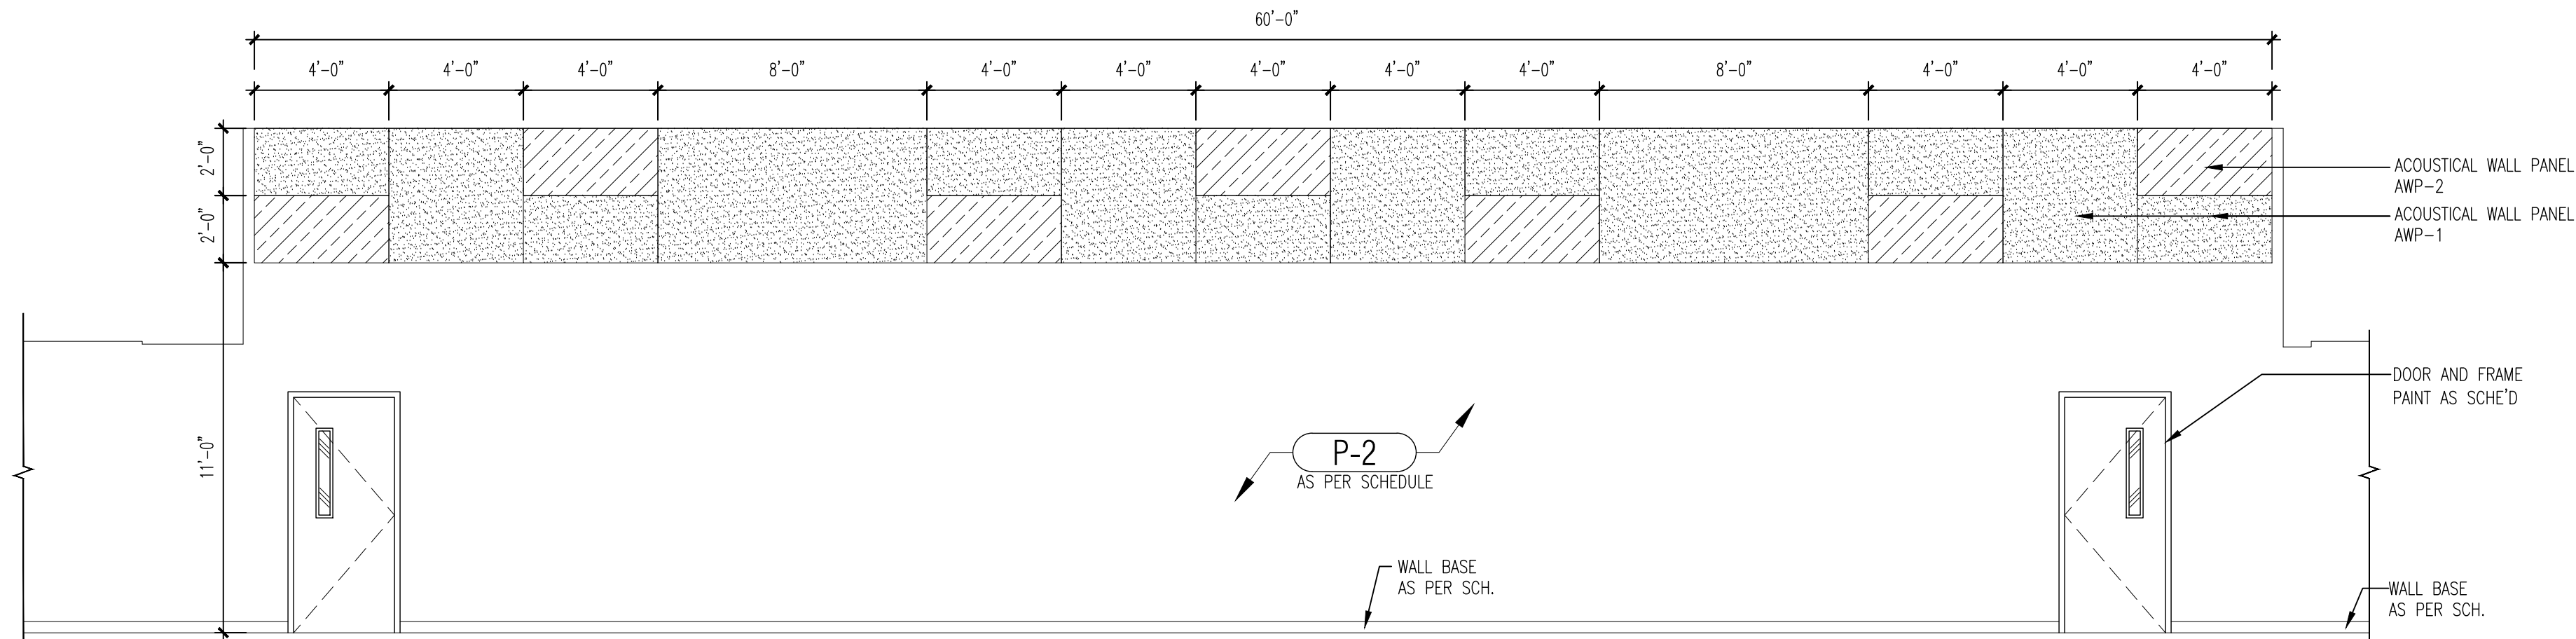

4 DINING ELEVATION
A-706 Scale: 1/4" = 1'-0"

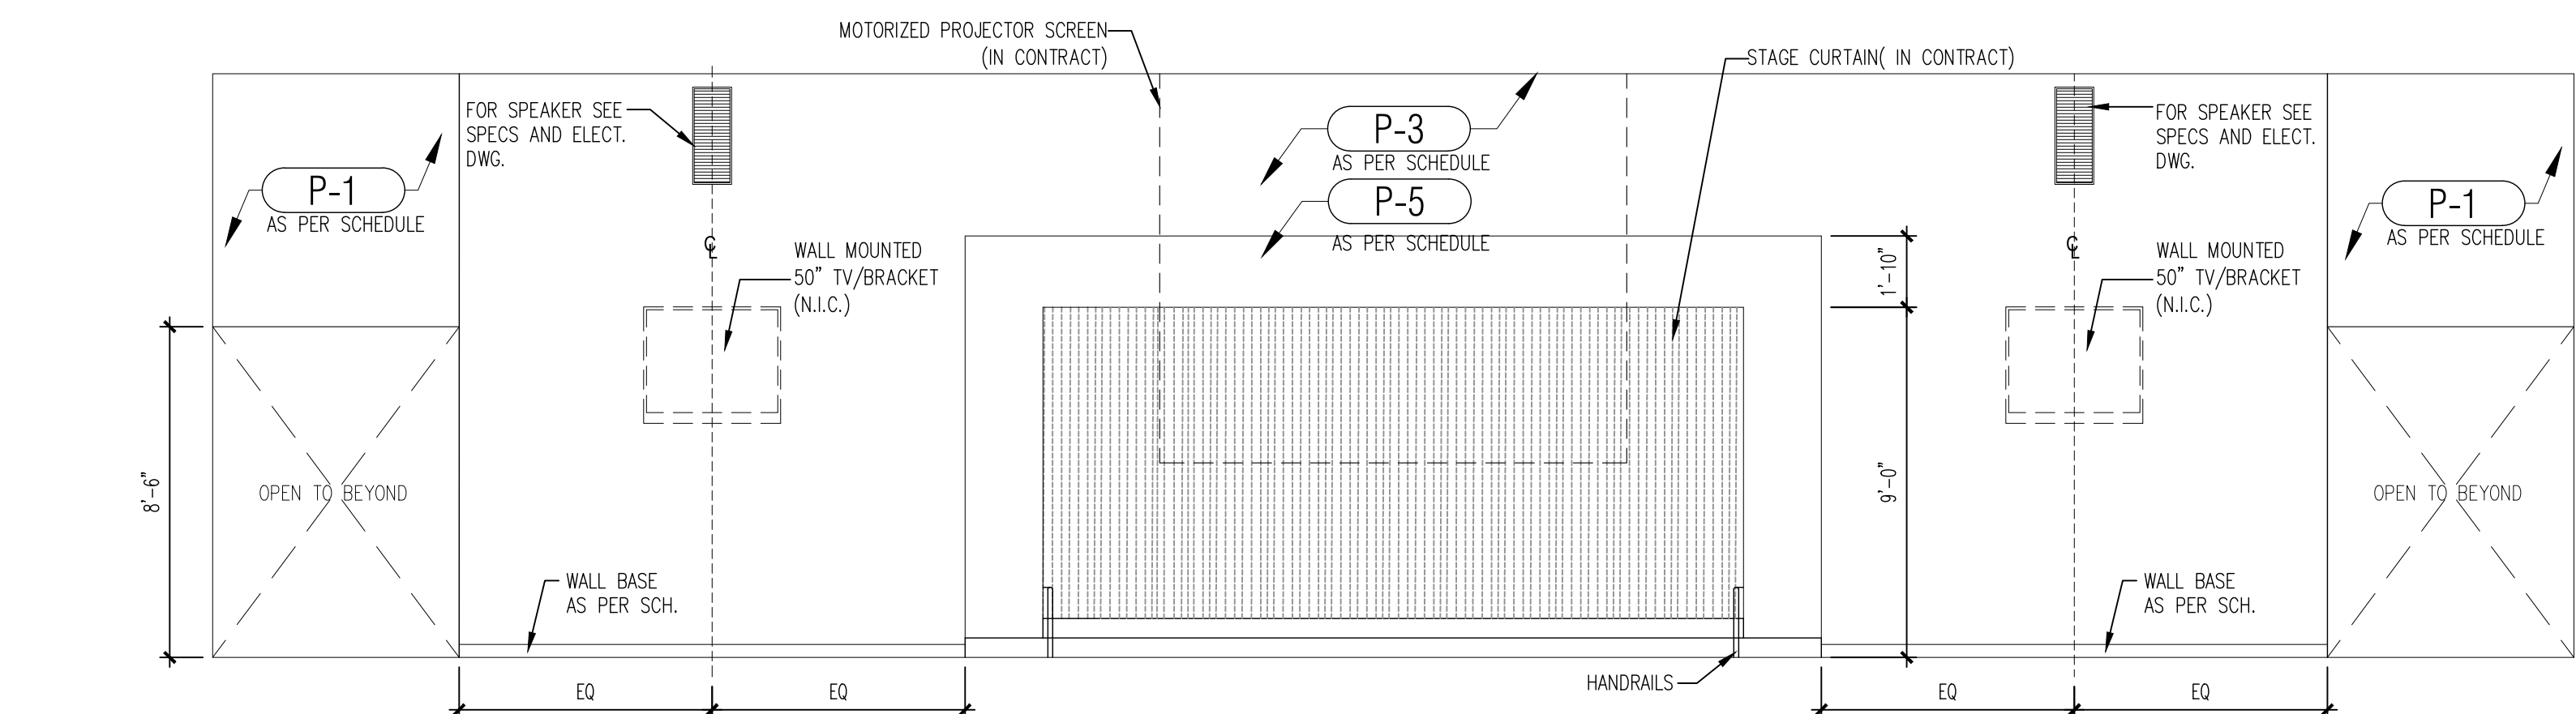

5 DINING ELEVATION
A-706 Scale: 1/4" = 1'-0"

FURNITURE, FIXTURES & EQUIPMENT SCHEDULES

IN CONTRACT ITEMS (IC) F-XXXX						
NO.	DESCRIPTION	MANU/MODEL	SIZE	ELECT	PLUMB	GAS
F-3548	HEAVY DUTY ADJUSTABLE SHELVING		36" x 18" x 84"H			
F-4001	ITV HUB		36" x 8" x 36"	X		
F-4003	CEILING MOUNTED PROJECTOR BRACKET		36" x 8" x 36"	X		
F-4008	FIRE SAFETY BLANKET	LARSEN NO. FB 68-6 SERIES	68" x 8-1/4" x 4'D			
F-4011	LIBRARY SHELVING		36" x 12" x 42"H			
F-4012	LIBRARY SHELVING		36" x 12" x 30"H			
F-4013	LIBRARY SHELVING		36" x 12" x 66"H			
F-4014	ADJUSTABLE LIBRARY SHELVING		36" x 18" x 84"H			
F-4200	ITV HUB		36" x 8" x 36"	X		
F-4035	MOTORIZED PROJECTOR SCREEN			X		
F-4036	OVERHEAD TRACK LIGHTING			X		
F-4198	CLOCK SPEAKER			X		
F-5000	TACKBOARD	CLARIDGE OR EQUAL	4'-0" x 4'-0"			W/MARKER TRAY AND MAP RAIL
F-5035	COMBINATION TACKBOARD/MARKERBOARD	CLARIDGE OR EQUAL	6'-0" x 4'-0"			
F-5037	MARKERBOARD	CLARIDGE OR EQUAL	4'-0" x 4'-0"			
F-5066	COMBINATION TACKBOARD/MARKERBOARD	CLARIDGE OR EQUAL	8'-0" x 4'-0"			
F-8001	TEACHER CALL BOX			X		
F-9000	BOOK DETECTION SYSTEM	CHECKPOINT	SEE MANUFACTURER SPEC.	X		MODEL: LIBERTY FX_MEDIA AREA

NOT IN CONTRACT ITEMS (NIC) XX-XXX						
NO.	DESCRIPTION	MANU/MODEL	SIZE	ELECT	PLUMB	GAS
AV-676	TELEVISION AND BRACKET INSTALLATION	TROXELL INSTALLER		X		
AV-677	PROJECTION TABLE CART		24" x 18" x 34"			
AV-678	ACTIVEBOARD TOUCH	PROMETHEAN / ABMT588UST	71" x 41"	X		
AV-621	CLASSROOM SOUND SYSTEM	ACHEVER MDL#CAE-20WPA	T.B.D.	X		
AV-622	TELEVISION EXTERNAL TUNER/ADAPTER	AVERMEDIA/ MT60XH11	T.B.D.	X		
AV-632	PROJECTION SYSTEM	NEC/ M311X	T.B.D.	X		
AV-674	TV UNIVERSAL 30"	TOCHIBA / 50L1350U		X		
AV-676	TV UNIVERSAL WALL MOUNT	PEPPERLESS/SA740P AND/OR ST650		X		
AV-677	TELEVISION 32" FLAT PANEL	SAMSUNG / MD32C		X		
AV-680	MIC BOX			X		
AV-681	CAMERA			X		
AV-682	PROMPTER			X		
AV-683	CONSOLE (3 STATIONS)			X		
AV-684	ITV RACK	70"H x 24"W x 26"D		X		
CO-020	COMPUTER MAINSTREAM WITH MONITOR	T.B.D.		X		
CO-025	LASER PRINTER, BASIC NETWORK DUPLEXING	HP / P2055DN 070-1104	T.B.D.	X		
DC-004	CHAIR, DISCOVERY SERIES ERGONOMIC	ARTCO-BELL/ D10B	16"			SEAT AND LEG T.B.D.
DC-006	CHAIR, DISCOVERY SERIES ERGONOMIC	ARTCO-BELL/ D10A	18"			SEAT AND LEG T.B.D.
DC-008	CHAIR EXECUTIVE HIGH BACK	HON - 2071BK	T.B.D.			
DC-009	CHAIR - PADDED SEAT	HON - H1081	T.B.D.			
DC-010	GUEST CHAIR	HON - 2304N	T.B.D.			
DC-012	LOUNGE CHAIR					
DC-013	TASK CHAIR PNEUMATIC-BACK HEIGHT SWIVEL	HON- H7701.S				
DC-016	TEACHER'S SWIVEL CHAIR	SCHOLARSHIP/ SC110P	T.B.D.			
DC-019	CRENZIA	T.B.D.	72"W x 24"D x 29-1/2"H			
DC-023	DESK - EXECUTIVE	T.B.D.	72"W x 24"D x 29-1/2" H			
DC-024	DESK - SHAPE	HON OR EQUAL 105 SERIES	66"W x 30"D x 29" H			
DC-025	STUDENT DESK					
DC-026	DESK, PUPIL OPEN FRONT	VRCO/ 785MBB-MPL385	18"D x 24"W/ ADJ 22"-30"H			BLACK, FUSION, MAPLE TOP
DC-027	DESK, TEACHERS, SINGLE PEDESTAL	HON-H88251	48"W x 30"D			TAN METAL W/OAK LAMINATE TOP
DC-040B	TABLE-X BASE	HON - H8836.P				
DC-0401	TABLE-SQUARE TOP	HON - H103036	36"W x 36"D			
DC-042	TABLE-ART & PLANNING	SHAIN/SHOP-BILT #1300743705	60"W x 42"D x 36"H			
DC-043	TABLE-CLASSROOM	VRCO- 483060	30"W x 60"D x ADJ HEIGHT			BIRCH/MAPLE TOP
DC-046	TABLE - CONFERENCE	HON/DOBAL - HTL4284	84" x 42"W/36"W AT END)x 29"H			BIRCH/MAPLE TOP
DC-048	TABLE - END	HON - H80193	24"x 20"Wx 20"H			BIRCH/MAPLE TOP
DC-054	TABLE - STUDENT	VRCO				
DC-060	TABLE/BENCH - CONVERTIBLE	MIDWEST / T88-PT 012-KK01				DINING/MULTIPURPOSE
DC-061S	STOOL, TASK, ADJUSTABLE HGT	JC WHITE/HON H7705				
DC-078	WOOD STOOL	PRIDE #30				
DC-088	CHAIR EXECUTIVE MID BACK	HON	T.B.D.			CONFERENCE ROOM
DC-097	BOW FRONT DESK SHELL	HON / H10596	72"W x 36"D x 29"H			
DC-103	CHAIR - WOOD W/RACK UNDER SEAT	JASPER CHAIR	18"			
DC-165	TABLE - LIBRARY STUDY TABLE	MARK PRODUCTS	42"W x 42"D x 29"H			
DC-177	TABLE - COMPUTER	VRCO #873060	24"W x 60"D x ADJ HEIGHT	X		
FA-009	COUCH, RECOVERY	WINCO / 855-03	24"W x 72" x 22"H			CLINIC
FS-011	MICROWAVE, 1.2 CU. FT	KENMORE # 20-69129	21-7/8"W X 12-1/2"H X 17-7/8"D	X		
FS-013	K2S WATER	KENMORE # 46-48-8959		X		
FS-027	VENDING MACHINE	FWE / PH-1826-18U	30-1/2"W x 33-1/4"D x 69"H			
LC-021	CABINET, STORAGE STEEL	HON - H5C1872L	36"W x 18"D x 72"H			
LC-048	SAFE - 90 MIN FIRE RATED	MUTUAL GV-4520	51"W x 26"W x 29"D (1930 lbs)			
LE-004	BOOK TRUCK, 3 FLAT SHELVES	BRETFORD F336	24" x 28" x 42"H			
LE-005	BOOK TRUCK, 6 SLOPING SHELVES	BRETFORD V336	24" x 18" x 42"H			
LE-006	BOOKCASE	HON - H105534	36"W x 13"D x 57-1/8"H			THICK SHELVES
LE-018	COMPUTER CARROL	INSTITUTIONAL PRODUCTS	60"W x 30"D x 36"H	X		
MM-009	SCREEN, 3-PANEL	WINCO / 02-50-3313	69" x 61"	X		CLINIC
NIC-0001	TECHNOLOGY CENTER	T.B.D.		X		
NIC-1000	COMPUTER TABLE		30" x 24"	X		
NIC-4034	CEILING MOUNTED PROJECTOR	T.B.D.		X		
NIC-4035	AV SCREEN & BRACKET	T.B.D.	161" x 10"H			
NIC-4000	AREA RUG		6' x 6'			
NIC-4001	KID OTTOMAN					
OF-002	FAX MACHINE	BROTHER BR72820		X		
OF-003	FILE CABINET	HON - H212C.P	18-1/4"W x 28-1/2"D x 29"H			
OF-005	FILE CABINET VERTICAL 4-DRAWER LEGAL	HON - H214C.P	18-1/4"W x 28-1/2"D x 52" H			
OF-006	FILE CABINET LATERAL 2-DRAWER	HON - H682.L	18"D x 36"D x 28" H			
OF-007	FILE CABINET LATERAL 5-DRAWER	HON - H685.L	36"W x 19-1/4"D x 64"H			
OF-018	SHREDDER WITH BASKET	GBC / 85X	14"W x 12"D x 18"H	X		


NOTES:
1. NOT IN CONTRACT NUMERICAL SEQUENCE REFLECT MIAMI DADE COUNTY PUBLIC SCHOOLS PRELIMINARY FF&E LIST DATED 1/20/2014.
2. COORDINATE ALL N.I.C. FF&E WITH MDCPS FOR FINAL LOCATIONS AND SELECTIONS

LEGEND		MOUNTING HEIGHTS FOR INSTRUCTIONAL BOARDS	
IN-CONTRACT F.F.E.			
F-1000	TABLES	PRE-K-3RD	1'-4" AFF OVERALL 5' BOARD HGT
F-2000	WALL & BASE CABINERY	PRE-K-3RD	2'-4" AFF OVERALL 4' BOARD HGT
F-3000	SHELVING	4th GRADE	2'-6" AFF OVERALL 4' BOARD HGT
F-3500	METAL SHELVING	MIDDLE	2'-9" AFF OVERALL 4' BOARD HGT
F-4000	EQUIPMENT	STAFF	3'-0" AFF OVERALL 4' BOARD HGT
F-5000	INSTRUCTIONAL AIDS		
F-6000	CHAIRS		
F-7000	SCIENCE EQUIPMENT		
F-8000	COM EQUIPMENT		
F-9000	SITE EQUIPMENT		
IN-CONTRACT CASEWORK		TYPE OR STYLE refer to DWGS, A-222 for details	
B	BASE	O	OPEN
C	CABINET	P	PANEL
D	DRAWERS	Q	COMBINATION LOWER/UPPER
E	VENTED	R	COUNTER
F	FULL LENGTH-WALL-WALL	S	SLIDING-SHELVES
G	DISH CABINET/LINENS	T	TABLE
K	DESK	U	UPPER
L	SPECIAL OR CUSTOM	V	VERTICAL DIVIDERS
M	WALLBOXES	W	WALL
N	FALSE PANEL		

- GENERAL NOTES**
- FOR TOILET ROOMS, REFER TO DRAWINGS A-712 & A-713 FOR ENLARGED PLANS AND ELEVATIONS.
 - FOR TOILET ROOM PROGRAM SPACE ACCESSORIES AND FOR GENERAL MOUNTING HEIGHTS, REFER TO SHEETS A-700.
 - FOR CASEWORK, ELEVATIONS AND DETAILS, REFER TO DRAWINGS A-750 & A-751.
 - REFER TO THE FOLLOWING SPECIFICATION SECTIONS FOR MANUFACTURERS AND MODEL NUMBERS NOT SHOWN ABOVE:
 - 10100 Visual Display Board And Display Cases (including tackboards)
 - 10101 Tackable Wall System
 - 10105 Plastic Toilet Partitions And Shower Screens
 - 10190 Cubicle Curtain Track
 - 10400 Identifying Devices
 - 10605 Metal Lockers And Benches
 - 10520 Fire Protection Speciales
 - 10675 Metal Storage Shelving And Cabinets
 - 11450 Residential Appliances
 - 12354 Laboratory Casework And Equipment
 - 12364 Musical Equipment Storage
 - 12710 Auditorium Seating
 - 12760 Telescoping Gymnasium Seating
 - ALL UPPER AND LOWER CABINETS TO HAVE ROUNDED CORNERS.
 - ALL INTERIOR FINISHES SHALL COMPLY WITH THE REQUIRED CLASSIFICATIONS AS DESCRIBED IN THE FLORIDA FIRE PREVENTION CODE. ALL INTERIOR FINISHES TO BE CLASS "A".
 - PROVIDE ALL NECESSARY BLOCKING AND BACKING AT PARTITIONS ALONG ALL CABINET AREAS AS REQUIRED TO SUSTAIN 75LBS PER LINEAR FEET OF SHELVING/CASEWORK AS PER AIA STANDARDS. SEE SPECIFICATIONS.


CHECKED BY: LR. DRAWN BY: C.V.

CONSULTANT INFO:

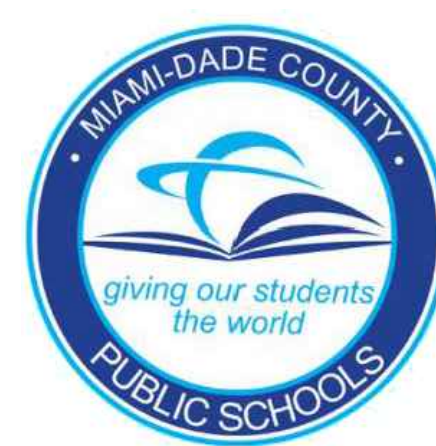


NEW ELEMENTARY SCHOOL (K-5)
VENETIAN PARC WEST
SOUTHWEST 157th AVENUE and 174th STREET
MIAMI, FL. 33187
MDCPS PROJECT No. 01892600


KEY PLAN

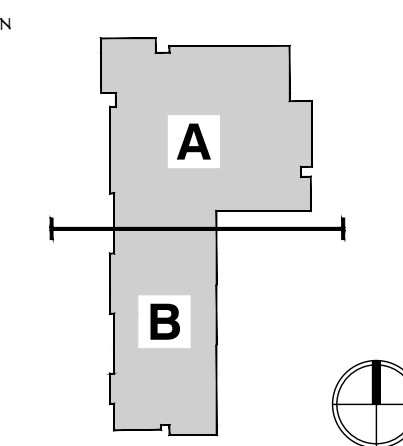

CONSULTANT INFO:

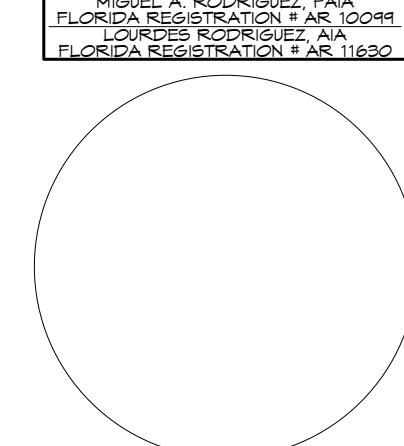


RODRIGUEZ ARCHITECTS INCORPORATED
2121 PONCE DE LEON BLVD. STE 1010
CORAL GABLES, FL. 33134
TEL: (305) 448-3373
FAX: (305) 448-3374

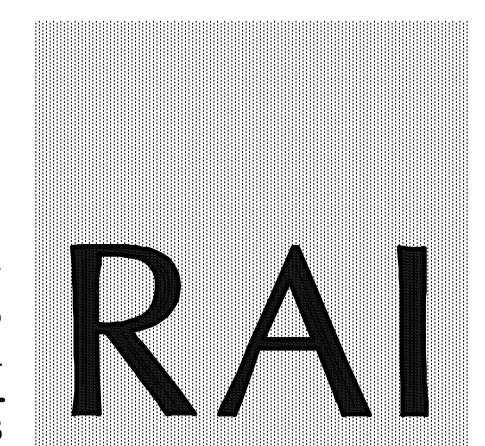

REVISIONS:


REVISIONS:

DRAWING TITLE: DINING MULTIPUR. RM. ELEVATIONS
SCALE AS NOTED
ISSUE DATE: 12/16/19 PROJECT NO: 1906
SHEET: A-706

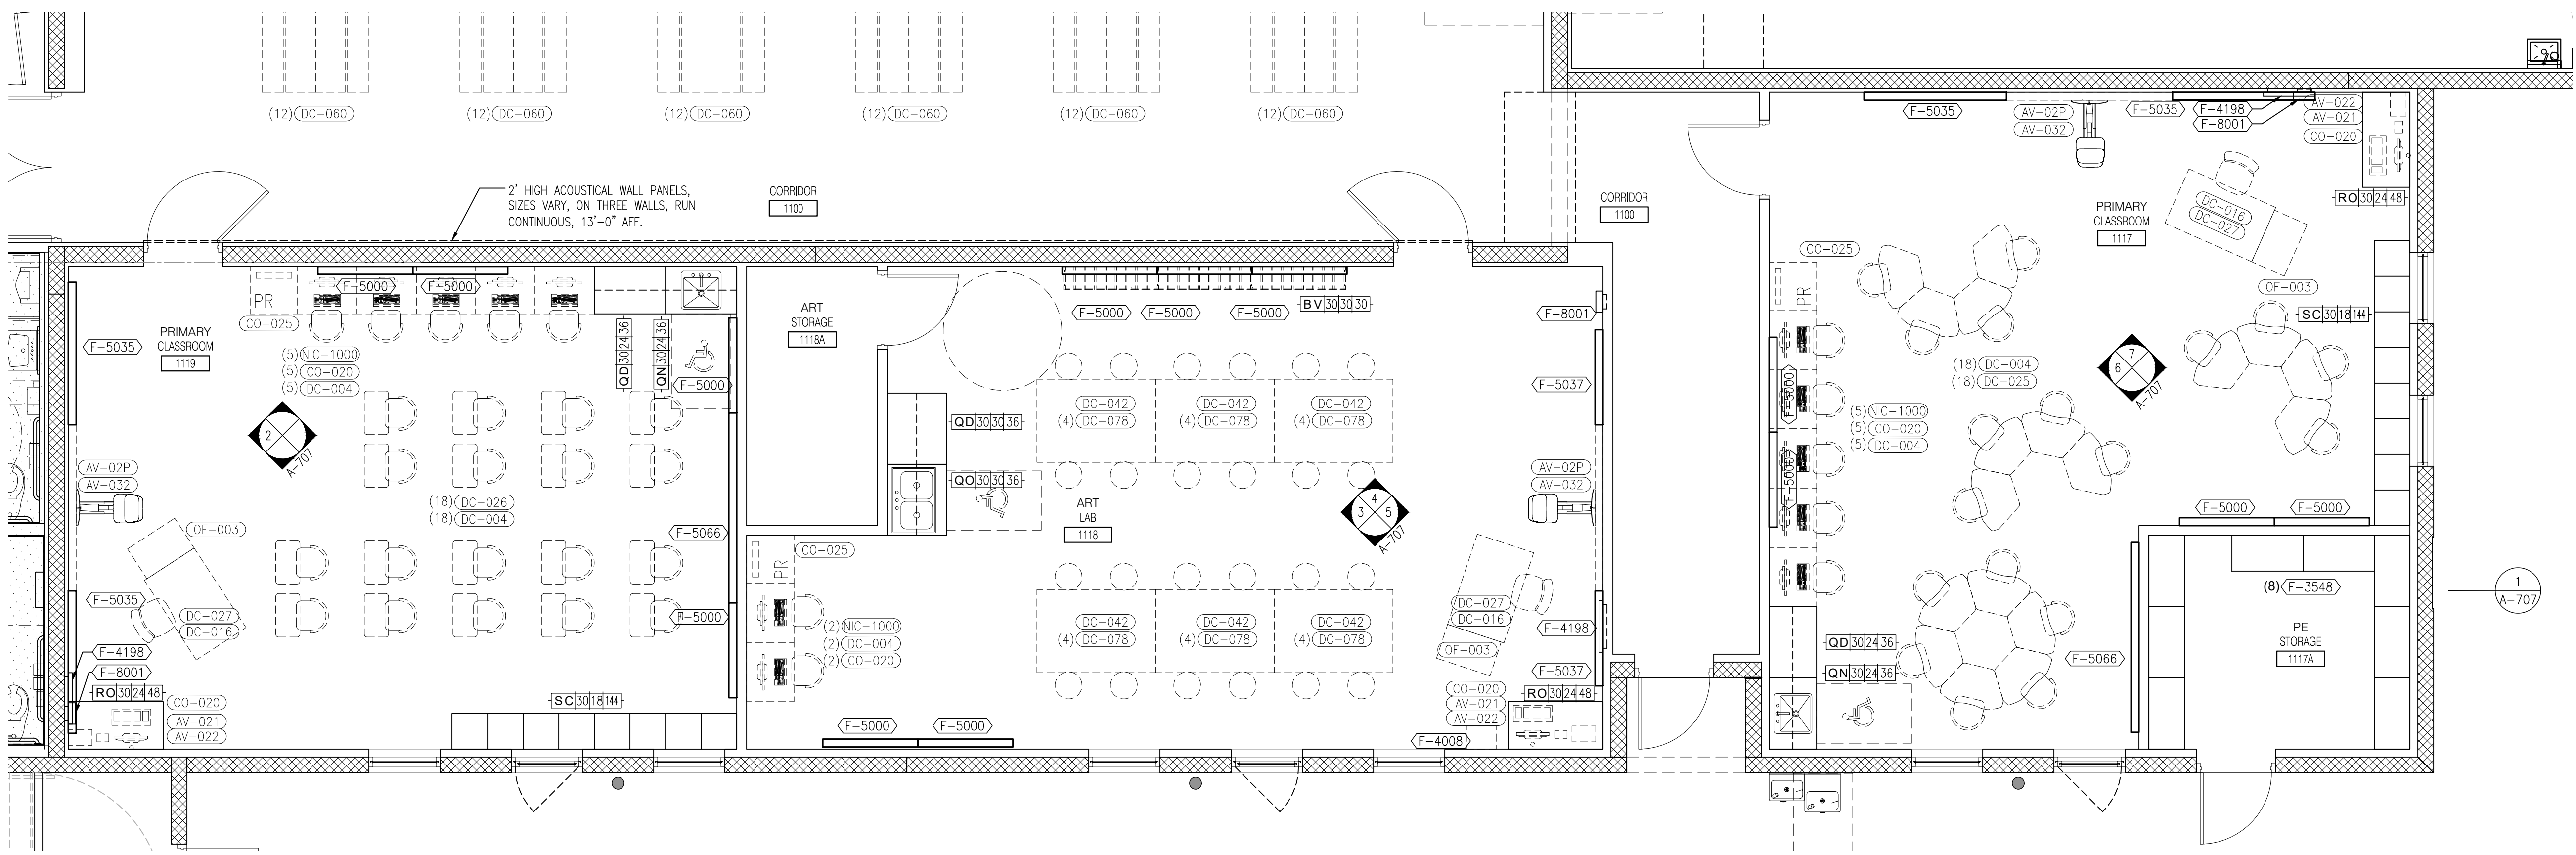


1 ENLARGED FIRST FLOOR ART LAB, LANGUAGE LAB & DISCOVERY LAB

A-707 Scale: 1/4" = 1'-0"

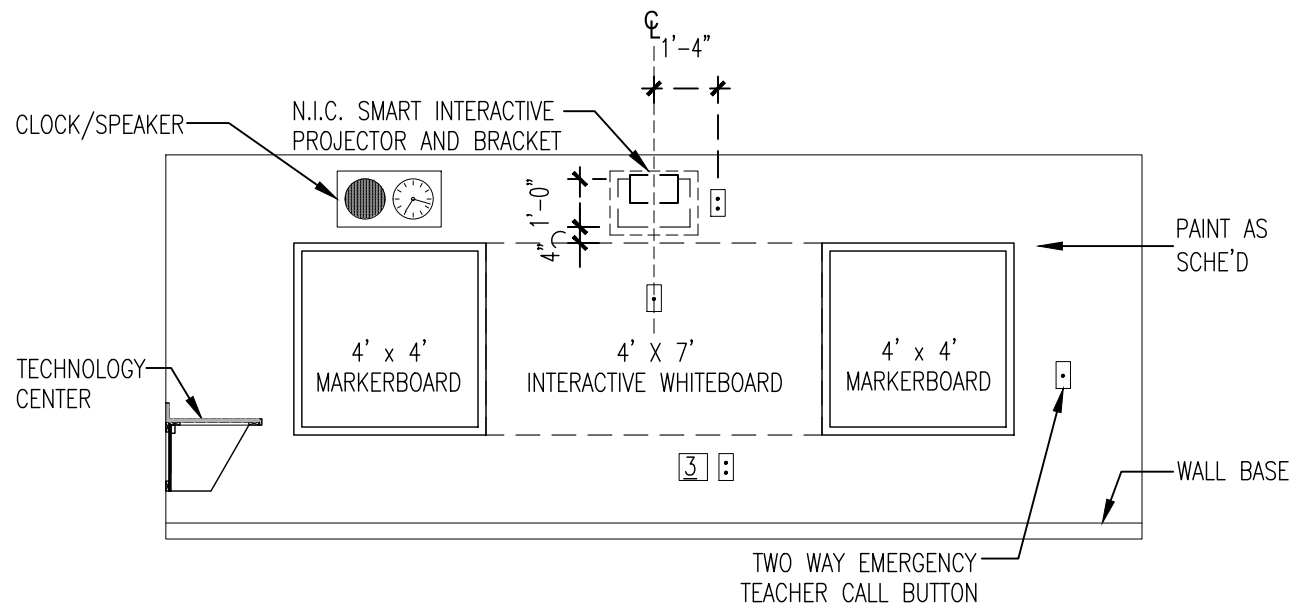


2 PRIMARY CLASSROOM ELEVATION

A-707 Scale: 1/4" = 1'-0"

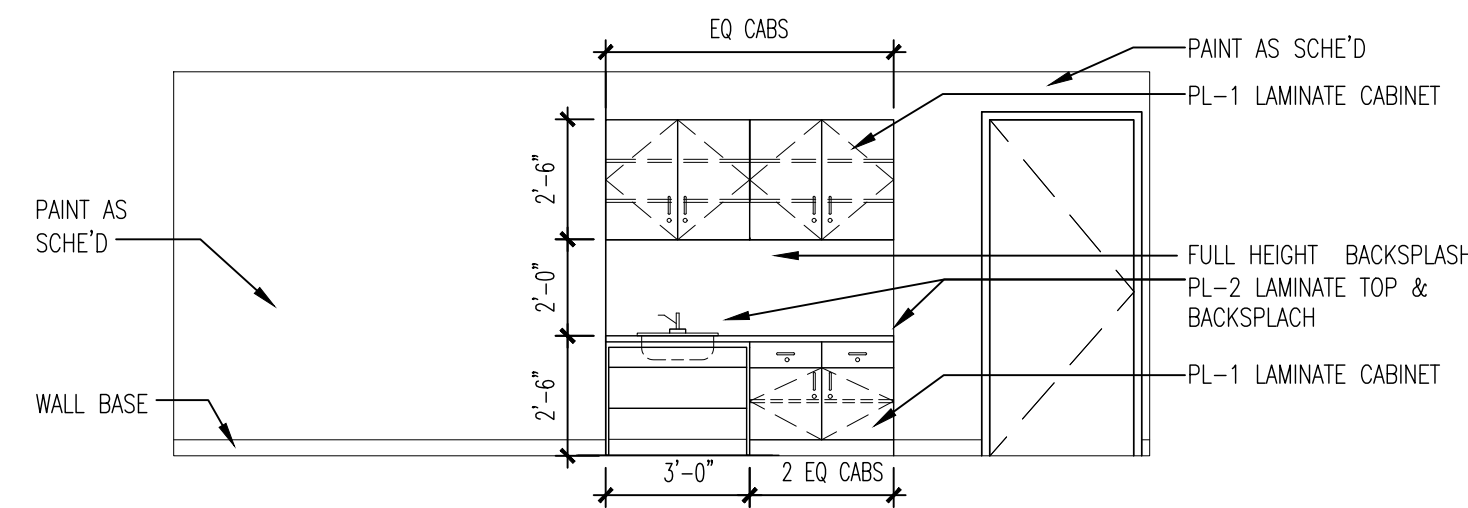

3 ART LAB ELEVATION

A-707 Scale: 1/4" = 1'-0"

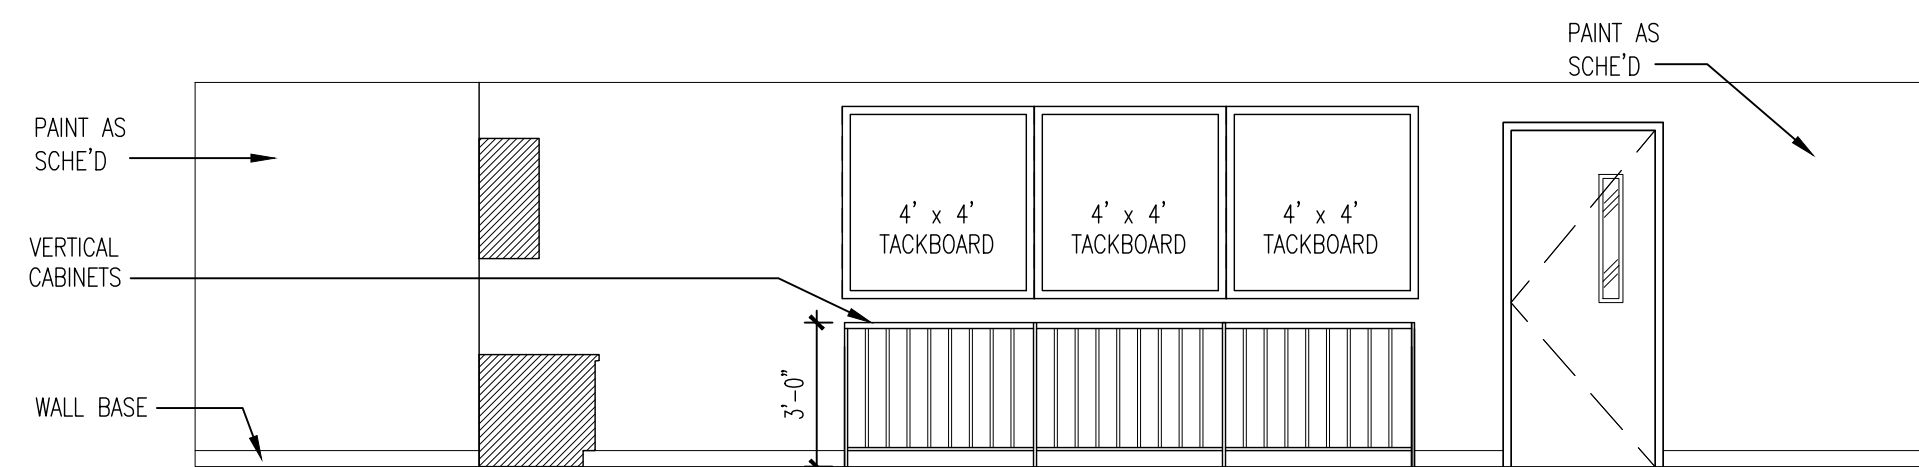


4 ART LAB ELEVATION

A-707 Scale: 1/4" = 1'-0"


5 ART LAB ELEVATION

A-707 Scale: 1/4" = 1'-0"

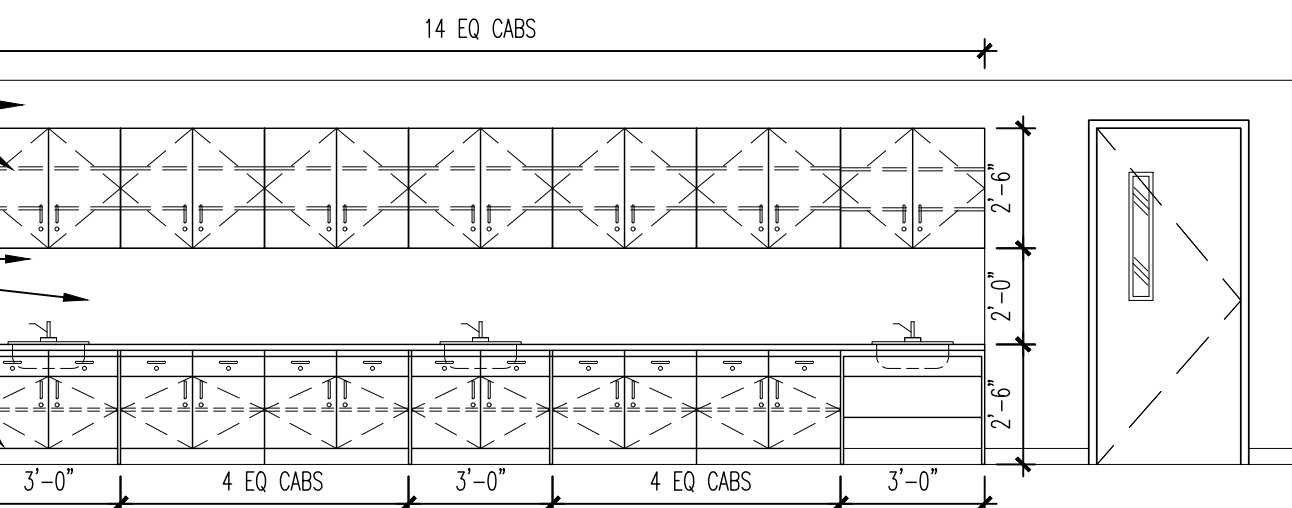

6 PRIMARY CLASSROOM ELEVATION

A-707 Scale: 1/4" = 1'-0"

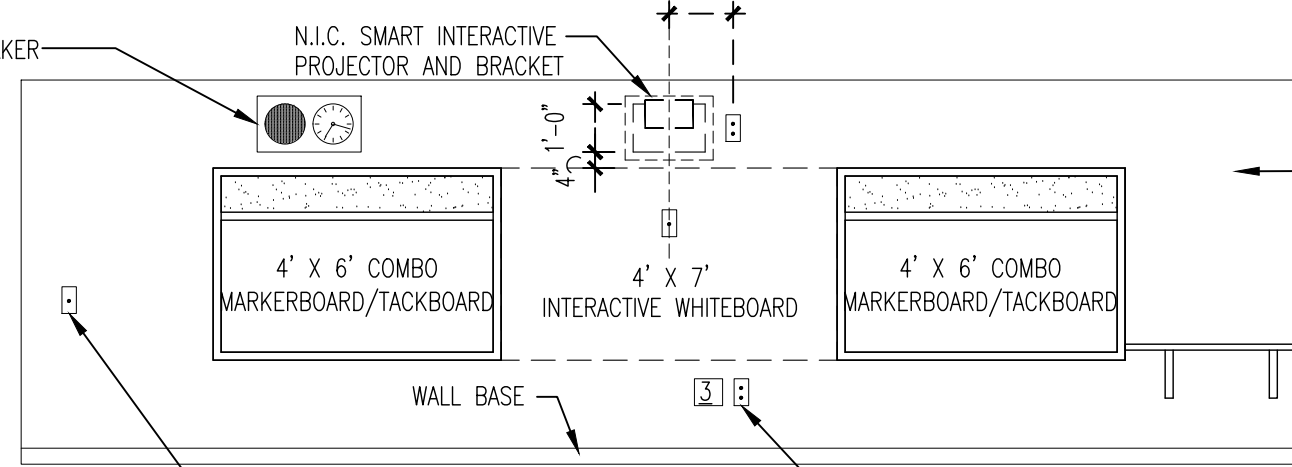

7 PRIMARY CLASSROOM ELEVATION

A-707 Scale: 1/4" = 1'-0"

FURNITURE, FIXTURES & EQUIPMENT SCHEDULES

IN CONTRACT ITEMS (IC)						
NO.	DESCRIPTION	MANU./MODEL	SIZE	ELECT	PLUMB	GAS
F-3548	HEAVY DUTY ADJUSTABLE SHELVING		36" x 18" x 84" H			
F-4001	TV HUB		36" W x 8" D x 36" H	X		
F-4003	CEILING MOUNTED PROJECTOR BRACKET			X		
F-4008	FIRE SAFETY BLANKET	LARSEN NO. FB 68-6 SERIES	68" W x 8-1/4" W x 4' D			
F-4011	LIBRARY SHELVING		36" W x 12" D x 42" H			
F-4012	LIBRARY SHELVING		36" W x 12" D x 30" H			
F-4013	LIBRARY SHELVING		36" W x 12" D x 60" H			
F-4014	ADJUSTABLE LIBRARY SHELVING		36" x 18" x 84" H			
F-4200	TV HUB		36" W x 8" D x 36" H	X		
F-4035	MOTORIZED PROJECTOR SCREEN			X		
F-4036	OVERHEAD TRACK LIGHTING			X		
F-4198	CLOCK SPEAKER			X		
F-5000	TACKBOARD	CLARIDGE OR EQUAL	4'-0" x 4'-0"			W/MARKER TRAY AND MAP RAIL
F-5035	COMBINATION TACKBOARD/MARKERBOARD	CLARIDGE OR EQUAL	6'-0" x 4'-0"			
F-5037	MARKERBOARD	CLARIDGE OR EQUAL	4'-0" x 4'-0"			
F-5066	COMBINATION TACKBOARD/MARKERBOARD	CLARIDGE OR EQUAL	8'-0" x 4'-0"			
F-8001	TEACHER CALL BOX			X		
F-9000	BOOK DETECTION SYSTEM	CHECKPOINT	SEE MANUFACTURER SPEC.	X		MODEL: LIBERTY PX_MEDIA AREA

NOT IN CONTRACT ITEMS (NIC) (XX-XXX)						
NO.	DESCRIPTION	MANU./MODEL	SIZE	ELECT	PLUMB	GAS
AV-076	TELEVISION AND BRACKET INSTALLATION	TROKELL INSTALLER		X		
AV-017	PROJECTOR TABLE CART	PROMETHEAN / ARMTSTBRUST	24" x 18" x 34" H			
AV-029	ACTIVBOARD TOUCH PANEL	PROMETHEAN / ARMTSTBRUST	71" x 4" H			
AV-021	CLASSROOM SOUND SYSTEM	ACHEVER M04EAC-20WPA	T.B.D.	X		
AV-022	CLASSROOM EXTERNAL TUNER/ADAPTER	ACHEVER M04EAC-20WPA	T.B.D.	X		
AV-032	PROJECTOR SYSTEM	NEC / M311X	T.B.D.	X		
AV-074	TV UNIVERSAL WALL MOUNT	TECHNISCHE / S01359U		X		
AV-077	TELEVISION 32" FLAT PANEL	PEERLESS/SATOP AND/OR STE50		X		
AV-080	MIC BOX	SAMSUNG / MD32C		X		
AV-081	CAMERA			X		
AV-082	PROMPTER			X		
AV-083	CONSOLE (3 STATIONS)			X		
AV-084	TV RACK		70" H x 24" W x 26" D			
CO-020	COMPUTER MAINSTREAM WITH MONITOR	T.B.D.	T.B.D.	X		
CO-025	LASER PRINTER, BASIC NETWORK DUPLEXING	HP / P2055DN 070-L104	T.B.D.	X		
DC-004	CHAIR, DISCOVERY SERIES ERGONOMIC	ARTCO-BELL/ D10A	16"			SEAT AND LEG T.B.D.
DC-006	CHAIR, DISCOVERY SERIES ERGONOMIC	ARTCO-BELL/ D10A	18"			SEAT AND LEG T.B.D.
DC-008	CHAIR, EXECUTIVE HIGH BACK	HON - 2077BK	T.B.D.			
DC-009	CHAIR - PADDED SEAT	HON - H1081	T.B.D.			
DC-010	GUEST CHAIR	HON - 2304N	T.B.D.			
DC-012	LOUNGE CHAIR					
DC-013	TASK CHAIR PNEUMATIC-BACK HEIGHT SWIVEL	HON - H7701.S				
DC-016	TEACHER'S SWIVEL CHAIR	SCHOLARCRAFT/ SC110P	T.B.D.			
DC-019	CRENDENZA	T.B.D.	72" W x 24" D x 29-1/2" H			
DC-023	DESK - EXECUTIVE	T.B.D.	72" W x 24" D x 29-1/2" H			
DC-024	DESK L-SHAPE	HON OR EQUAL 105 SERIES	66" W x 30" D x 29" H			
DC-025	STUDENT DESK					
DC-026	DESK, PUPIL OPEN FRONT	VRICO/ 785MBB-MPL385	18" D x 24" W x ADJ 22"-30" H			BLACK, FUSION, MAPLE TOP
DC-027	DESK, TEACHERS, SINGLE PEDESTAL	HON-H88251	48" W x 30" D			TAN METAL W/OAK LAMINATE TOP
DC-4008	TABLE-X BASE	HON - H8836.P	36" W x 36" D			
DC-4010	TABLE-SQUARE TOP	HON - H103560	36" W x 36" D			
DC-042	TABLE-ART & PLANNING	SHAIN/SHOP-BLT #1300743705	60" W x 42" D x 36" H			
DC-043	TABLE-CLASSROOM	VRICO - 483060	30" W x 60" D x ADJ HEIGHT			BIRCH/MAPLE TOP
DC-046	TABLE-CONFERENCE	HON/GORAL - H14284	84" x 42" W(36" W AT ENDS) x 29" H			BIRCH/MAPLE TOP
DC-048	TABLE - END	HON - H80193	24" x 28" W x 20" H			BIRCH/MAPLE TOP
DC-054	TABLE - STUDENT	VRICO				
DC-060	TABLE/BENCH - CONVERTIBLE	MIDWEST / T88-PT 012-KK01				DINING/MULTIPURPOSE
DC-0615	STOOL, TASK, ADJUSTABLE HGT	JC WHITE/HON H7705				
DC-078	WOOD STOOL	PRIDE #30				
DC-088	CHAIR EXECUTIVE MID BACK	HON	T.B.D.			CONFERENCE ROOM
DC-097	BOW FRONT DESK SHELL	HON / H10596	72" W x 36" D x 29" H			
DC-103	CHAIR - WOOD W/RACK UNDER SEAT	JASPER CHAIR	18"			
DC-165	TABLE - LIBRARY STUDY TABLE	MARK PRODUCTS	42" W x 42" D x 29" H			
DC-177	TABLE - COMPUTER	VRICO #873060	24" W x 60" D x ADJ HEIGHT	X		
FA-009	COUCH, RECOVERY	WINCO / 855-03	24" W x 72" L x 22" H			CLINIC
FS-011	MICROWAVE, 1.2 CU. FT	KENMORE # 20-69129	21-7/8" W x 12-1/2" H x 17-7/8" D	X		
FS-013	ICE MAKER	KENMORE # 48-49599		X		
FS-027	VENDING MACHINE	FWE / PH-1826-18U	30-1/2" W x 33-1/4" D x 69" H			
LC-021	CABINET, STORAGE STEEL	HON - HSC1872.L	36" W x 18" D x 72" H			
LC-048	SAFE - 90 MIN FIRE RATED	MUTUAL GV-4520	51" H x 26" W x 29" (1930 lbs)			THICK SHELVES
LE-004	BOOK TRUCK, 3 FLAT SHELVES	BREITFORD F336	24" x 28" D x 47" H			
LE-005	BOOK TRUCK, 2 SLOPING SHELVES	BREITFORD V336	37" x 18" D x 42" H			
LE-006	BOOKCASE	HON - H105534	36" W x 13" D x 57-1/8" H			
LE-018	COMPUTER CARROL	INSTITUTIONAL PRODUCTS	60" W x 30" D x 36" H	X		
MM-009	SOURCE, 3-PANEL	WINCO / 02-50-3313	69" x 81"	X		CLINIC
NIC-0001	TECHNOLOGY CENTER	T.B.D.		X		
NIC-1000	COMPUTER TABLE		30" x 24"	X		
NIC-4034	CEILING MOUNTED PROJECTOR	T.B.D.		X		
NIC-4035	AV SCREEN & BRACKET	T.B.D.	161" x 10" H			
NIC-4000	AREA RUG		6' x 6'			
NIC-4001	KID OTTOMAN					
OF-002	FAX MACHINE	BROTHER BR12820		X		
OF-003	FILE CABINET	HON - H212C.P.	18-1/4" W x 28-1/2" D x 29" H			
OF-005	FILE CABINET VERTICAL 4-DRAWER LEGAL	HON - H214C.P.	18-1/4" W x 28-1/2" D x 52" H			
OF-006	FILE CABINET LATERAL 2-DRAWER	HON - H682.L	18" D x 36" W x 28" H			
OF-007	FILE CABINET LATERAL 5-DRAWER	HON - H685.L	36" W x 19-1/4" D x 64" H			
OF-018	SHREDDER WITH BASKET	GBC / 85X	14" W x 12" D x 18" H	X		

NOTES:
1. NOT IN CONTRACT NUMERICAL SEQUENCE REFLECT MIAMI DADE COUNTY PUBLIC SCHOOLS PRELIMINARY FF&E LIST DATED 1/20/2014.
2. COORDINATE ALL N.I.C. FF&E WITH MDCPS FOR FINAL LOCATIONS AND SELECTIONS

LEGEND		MOUNTING HEIGHTS FOR INSTRUCTIONAL BOARDS	
IN-CONTRACT F.F.E.			
F-1000	TABLES	PRE-K-3RD	1'-4" AFF OVERALL 5' BOARD HGT
F-2000	WALL & BASE CABINETS	PRE-K-3RD	2'-4" AFF OVERALL 4' BOARD HGT
F-3000	SHELVING	4th GRADE	2'-6" AFF OVERALL 4' BOARD HGT
F-3500	METAL SHELVING	MIDDLE	2'-9" AFF OVERALL 4' BOARD HGT
F-4000	EQUIPMENT	STAFF	3'-0" AFF OVERALL 4' BOARD HGT
F-5000	INSTRUCTIONAL AIDS		
F-6000	CHAIRS		
F-7000	SCIENCE EQUIPMENT		
F-8000	GYM EQUIPMENT		
F-9000	SITE EQUIPMENT		
IN-CONTRACT CASEWORK		TYPE OR STYLE refer to DWGS, A-222 for details	
B	BASE	O	OPEN
C	CABINET	P	PANEL
D	DRAWERS	Q	COMBINATION LOWER/UPPER
E	VENTED	R	COUNTER
F	FULL LENGTH-WALL-WALL	S	SLOPING SHELVES
G	DISH CABINET/LINENS	T	TABLE
K	DESK	U	UPPER
L	SPECIAL OR CUSTOM	V	VERTICAL DIVIDERS
M	WALLBOXES	W	WALL
N	FALSE PANEL		

- GENERAL NOTES**
- FOR TOILET ROOMS, REFER TO DRAWINGS A-712 & A-713 FOR ENLARGED PLANS AND ELEVATIONS.
 - FOR TOILET ROOM PROGRAM SPACE ACCESSORIES AND FOR GENERAL MOUNTING HEIGHTS, REFER TO SHEETS A-700.
 - FOR CASEWORK, ELEVATIONS AND DETAILS, REFER TO DRAWINGS A-750 & A-751.
 - REFER TO THE FOLLOWING SPECIFICATION SECTIONS FOR MANUFACTURERS AND MODEL NUMBERS NOT SHOWN ABOVE:
10100 Visual Display Board And Display Cases (including tackboards)
10125 Tackable Wall System
10165 Plastic Toilet Partitions And Shower Screens
10190 Outside Curtain Track
10400 Identifying Devices
10505 Metal Lockers And Benches
10520 Fire Protection Specialties
10675 Metal Storage Shelving And Cabinets
11450 Residential Appliances
12354 Laboratory Casework And Equipment
12364 Medical Equipment Storage
12710 Auditorium Seating
12760 Telescoping Gymnasium Seating
 - ALL UPPER AND LOWER CABINETS TO HAVE ROUNDED CORNERS.
 - ALL INTERIOR FINISHES SHALL COMPLY WITH THE REQUIRED CLASSIFICATIONS AS DESCRIBED IN THE FLORIDA FIRE PREVENTION CODE. ALL INTERIOR FINISHES TO BE CLASS "A".
 - PROVIDE ALL NECESSARY BLOCKING AND BACKING AT PARTITIONS ALONG ALL CABINET AREAS AS REQUIRED TO SUSTAIN 75 LBS PER LINEAR FEET OF SHELVING/CASEWORK AS PER AIA STANDARDS. SEE SPECIFICATIONS.

CHECKED BY: LR. DRAWN BY: C.V.


CONSULTANT INFO:




NEW ELEMENTARY SCHOOL (K-5) VENETIAN PARC WEST

SOUTHWEST 157th AVENUE and 174th STREET
MIAMI, FL. 33187
MDCPS PROJECT No. 01892600


KEY PLAN

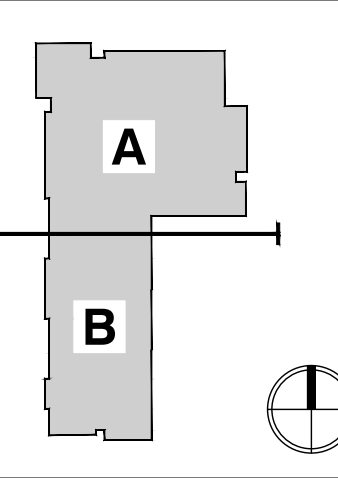

CONSULTANT INFO:

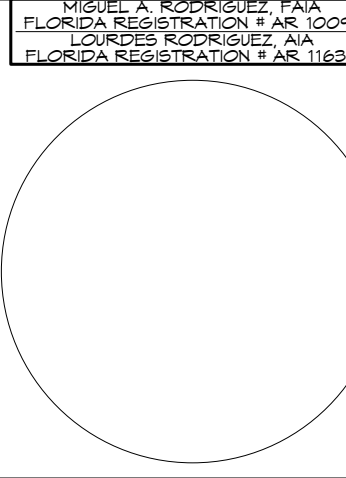

RODRIGUEZ ARCHITECTS INCORPORATED
2121 PONCE DE LEON BLVD. STE 1010
CORAL GABLES, FL. 33134
TEL: (305) 448-3373
FAX: (305) 448-3374

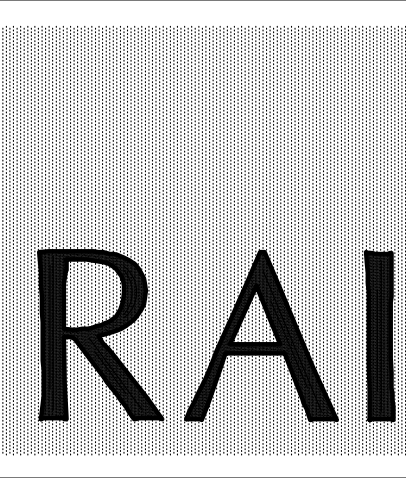

REVISIONS:

DRAWING TITLE:
ENL. 1ST FLOOR ART LAB & PRIMARY CLASSROOM

SCALE AS NOTED

ISSUE DATE: 12/16/19 PROJECT NO: 1906

SHEET: A-707



6. ALL INTERIOR FINISHES SHALL COMPLY WITH THE REQUIRED CLASSIFICATIONS AS DESCRIBED IN THE FLORIDA FIRE PREVENTION CODE. ALL INTERIOR FINISHES TO BE CLASS "A".
7. PROVIDE ALL NECESSARY BLOCKING AND BACKING AT PARTITIONS ALONG ALL CABINET AREAS AS REQUIRED TO SUSTAIN 75LBS PER LINEAR FEET OF SHELVING/CASEWORK AS PER AIA STANDARDS. SEE SPECIFICATIONS.


FURNITURE, FIXTURES & EQUIPMENT SCHEDULES

IN CONTRACT ITEMS (IC) F-XXXX						
NO.	DESCRIPTION	MANU./MODEL	SIZE	ELECT	PLUMB	GAS
F-3548	HEAVY DUTY ADJUSTABLE SHELVING		36" x 18" x 84"H			
F-4001	TV HUB		36" W x 8" D x 36" H	X		
F-4003	CEILING MOUNTED PROJECTOR BRACKET			X		
F-4008	FIRE SAFETY BLANKET	LARSEN NO. FB 68-6 SERIES	68" H x 8-1/4" W x 4" D			
F-4011	LIBRARY SHELVING		36" W x 12" D x 42" H			
F-4012	LIBRARY SHELVING		36" W x 12" D x 30" H			
F-4013	LIBRARY SHELVING		36" W x 12" D x 66" H			
F-4014	ADJUSTABLE LIBRARY SHELVING		36" W x 18" D x 84" H			
F-4200	TV HUB		36" W x 8" D x 36" H	X		
F-4035	MOTORIZED PROJECTOR SCREEN			X		
F-4036	OVERHEAD TRACK LIGHTING			X		
F-4198	CLOCK SPEAKER			X		
F-5000	TACKBOARD	CLARIDGE OR EQUAL	4'-0" x 4'-0"			W/MARKER TRAY AND MAP RAIL
F-5035	COMBINATION TACKBOARD/MARKERBOARD	CLARIDGE OR EQUAL	6'-0" x 4'-0"			
F-5037	MARKERBOARD	CLARIDGE OR EQUAL	4'-0" x 4'-0"			
F-5066	COMBINATION TACKBOARD/MARKERBOARD	CLARIDGE OR EQUAL	8'-0" x 4'-0"			
F-8001	TEACHER CALL BOX			X		
F-9000	BOOK DETECTION SYSTEM	CHECKPOINT	SEE MANUFACTURER SPEC.	X		MODEL: LIBERTY FX_MEDIA AREA

NOT IN CONTRACT ITEMS (NIC) XX-XXX						
NO.	DESCRIPTION	MANU./MODEL	SIZE	ELECT	PLUMB	GAS
AV-076	TELEVISION AND BRACKET INSTALLATION	TROXELL INSTALLER		X		
AV-017	PROJECTOR TABLE CART	PROMETHEAN / ABMTSTB8JST	24" x 18" D x 34" H			
AV-02P	ACTIVBOARD TOUCH	ACHEVER MDL4CAE-20WPA	71" x 41"	X		
AV-021	CLASSROOM SOUND SYSTEM	ACHEVER MDL4CAE-20WPA	T.B.D.	X		
AV-022	TELEVISION EXTERNAL TUNER/ADAPTER	ACHEVER MDL4CAE-20WPA	T.B.D.	X		
AV-032	PROJECTOR SYSTEM	NEC / M311X	T.B.D.	X		
AV-074	TV UNIVERSAL 30"	TOCHINE / 501359U		X		
AV-076	TV UNIVERSAL WALL MOUNT	PEPPERLESS/SA740P AND/OR ST650		X		
AV-077	TELEVISION 32" FLAT PANEL	SAMSUNG / MD32C		X		
AV-080	MIC BOX			X		
AV-081	CAMERA			X		
AV-082	PROMPTER			X		
AV-083	CONSOLE (3 STATIONS)			X		
AV-084	TV RACK		70" H x 24" W x 26" D			
CO-020	COMPUTER MAINSTREAM WITH MONITOR	T.B.D.	T.B.D.	X		
CO-025	LASER PRINTER, BASIC NETWORK DUPLEXING	HP / P2055DN 070-1104	T.B.D.	X		
DC-004	CHAIR, DISCOVERY SERIES ERGONOMIC	ARTCO-BELL / D10B	16"			SEAT AND LEG T.B.D.
DC-006	CHAIR, DISCOVERY SERIES ERGONOMIC	ARTCO-BELL / D10A	18"			SEAT AND LEG T.B.D.
DC-008	CHAIR, EXECUTIVE HIGH BACK	HON / 2071BK	T.B.D.			
DC-009	CHAIR - PADDED SEAT	HON - H1081	T.B.D.			
DC-010	GUEST CHAIR	HON - 2304N	T.B.D.			
DC-012	LOUNGE CHAIR					
DC-013	TASK CHAIR, PNEUMATIC-BACK HEIGHT SWIVEL	HON - H7701.S				
DC-016	TEACHER'S SWIVEL CHAIR	SCHOLARSHIP / SC110P	T.B.D.			
DC-019	CREDENZA		72" W x 24" D x 29-1/2" H			
DC-023	DESK - EXECUTIVE		72" W x 24" D x 29-1/2" H			
DC-024	DESK - SHAPE	HON OR EQUAL 105 SERIES	66" W x 30" D x 29" H			
DC-025	STUDENT DESK					
DC-026	DESK, PUPIL OPEN FRONT	VRCO / 785MB-MPL385	18" D x 24" W / ADJ 22"-30" H			BLACK, FUSION, MAPLE TOP
DC-027	DESK, TEACHERS, SINGLE PEDESTAL	HON-H88251	48" W x 30" D			TAN METAL W/OAK LAMINATE TOP
DC-040H	TABLE-X BASE	HON - H8836.P				
DC-040I	TABLE-SQUARE TOP	HON - H10336G	36" W x 36" D			
DC-042	TABLE-ART & PLANNING	SHAIN/SHOP-BILT #1300743705	60" W x 42" D x 36" H			
DC-043	TABLE-CLASSROOM	VRCO - 483060	30" W x 60" D x ADJ HEIGHT			BIRCH/MAPLE TOP
DC-046	TABLE - CONFERENCE	HON/DORAL - HTL4284	84" x 42" W/36" W AT END)x 29" H			BIRCH/MAPLE TOP
DC-048	TABLE - END	HON - H80193	24" x 20" W x 20" H			BIRCH/MAPLE TOP
DC-054	TABLE - STUDENT	VRCO				DINING/MULTIPURPOSE
DC-060	TABLE/BENCH - CONVERTIBLE	MIDWEST / T88-PT 012-KK01				
DC-061S	STOOL, TASK, ADJUSTABLE HGT	JC WHITE/HON H7705				
DC-078	WOOD STOOL	PRIDE #30				
DC-088	CHAIR EXECUTIVE MID BACK	HON	T.B.D.			CONFERENCE ROOM
DC-097	BOW FRONT DESK SHELL	HON / H10596	72" W x 36" D x 29" H			
DC-103	CHAIR - WOOD W/RACK UNDER SEAT	JASPER CHAIR	18"			
DC-165	TABLE - LIBRARY STUDY TABLE	MARK PRODUCTS	42" W x 42" D x 29" H			
DC-177	TABLE - COMPUTER	VRCO #873060	24" W x 60" D x ADJ HEIGHT	X		
FA-009	COUCH, RECOVERY	WINCO / 855-03	24" W x 72" x 22" H			CLINIC
FS-011	MICROWAVE, 1.2 CU. FT	KENMORE # 20-69129	21-7/8" W x 12-1/2" H x 17-7/8" D	X		
FS-013	K2S WAXER	KENMORE # 46-49599		X		
FS-027	VENDING MACHINE	FWE / PH-1826-18U	30-1/2" W x 33-1/4" D x 69" H			
LC-021	CABINET, STORAGE STEEL	HON - H5C1872L	36" W x 18" D x 72" H			
LC-048	SAFE - 90 MIN FIRE RATED	MUTUAL - GV-4520	51" H x 26" W x 29" D (1930 lbs)			THICK SHELVES
LE-004	BOOK TRUCK, 3 FLAT SHELVES	BREITFORD F336	24" x 28" D x 42" H			
LE-005	BOOK TRUCK, 8 SLOPING SHELVES	BREITFORD V336	37" x 18" D x 42" H			
LE-006	BOOKCASE	HON - H105534	36" W x 13" D x 57-1/8" H			
LE-018	COMPUTER CARROL	INSTITUTIONAL PRODUCTS	60" W x 30" D x 36" H	X		
MM-009	SCREEN, 3-PANEL	WINCO / 02-50-3313	69" x 61"	X		CLINIC
NIC-0001	TECHNOLOGY CENTER		T.B.D.	X		
NIC-1000	COMPUTER TABLE		30" x 24"	X		
NIC-4034	CEILING MOUNTED PROJECTOR		T.B.D.	X		
NIC-4035	AV SCREEN & BRACKET		161" x 10" H			
NIC-4000	AREA RUG		6' x 6'			
NIC-4001	KID OTTOMAN					
OF-002	FAX MACHINE	BROTHER BR72820		X		
OF-003	FILE CABINET	HON - H212C.P	18-1/4" W x 28-1/2" D x 29" H			
OF-005	FILE CABINET VERTICAL 4-DRAWER LEGAL	HON - H214C.P	18-1/4" W x 28-1/2" D x 52" H			
OF-006	FILE CABINET LATERAL 2-DRAWER	HON - H882.L	18" D x 36" W x 28" H			
OF-007	FILE CABINET LATERAL 5-DRAWER	HON - H885.L	36" W x 19-1/4" D x 64" H			
OF-018	SHREDDER WITH BASKET	GBC / 85X	14" W x 12" D x 18" H	X		

NOTES:
1. NOT IN CONTRACT NUMERICAL SEQUENCE REFLECT MIAMI DADE COUNTY PUBLIC SCHOOLS PRELIMINARY FF&E LIST DATED 1/20/2014.
2. COORDINATE ALL N.I.C. FF&E WITH MDGPS FOR FINAL LOCATIONS AND SELECTIONS

LEGEND		MOUNTING HEIGHTS FOR INSTRUCTIONAL BOARDS		GENERAL NOTES
IN-CONTRACT F.F.E.		PRE-K-3RD	4TH-6TH	
F-1000 TABLES		1'-4" AFF OVERALL 5' BOARD HGT		1. FOR TOILET ROOM, REFER TO DRAWINGS A-712 & A-713 FOR ENLARGED PLANS AND ELEVATIONS.
F-2000 WALL & BASE CABINETS		2'-4" AFF OVERALL 4' BOARD HGT		
F-3000 SHELVING		4th GRADE 2'-8" AFF OVERALL 4' BOARD HGT		2. FOR TOILET ROOM PROGRAM SPACE ACCESSORIES AND FOR GENERAL MOUNTING HEIGHTS, REFER TO SHEETS A-700.
F-3500 METAL SHELVING		MIDDLE 2'-9" AFF OVERALL 4' BOARD HGT		
F-4000 EQUIPMENT		STAFF 3'-0" AFF OVERALL 4' BOARD HGT		3. FOR CASEWORK, ELEVATIONS AND DETAILS, REFER TO DRAWINGS A-750 & A-751.
F-5000 INSTRUCTIONAL AIDS				
F-6000 CHAIRS				4. REFER TO THE FOLLOWING SPECIFICATION SECTIONS FOR MANUFACTURERS AND MODEL NUMBERS NOT SHOWN ABOVE: 10100 Visual Display Board And Display Cases (including tackboards) 10125 Tackable Wall System 10165 Plastic Toilet Partitions And Shower Screens 10190 Cubicle Curtain Track 10400 Identifying Devices 10605 Metal Lockers And Benches 10520 Fire Protection Speciales 10675 Metal Storage Shelving And Cabinets 11450 Residential Appliances 12354 Laboratory Casework And Equipment 12364 Musical Equipment Storage 12710 Auditorium Seating 12760 Telescoping Gymnasium Seating
F-7000 SCIENCE EQUIPMENT				
F-8000 CIVIL EQUIPMENT				5. ALL UPPER AND LOWER CABINETS TO HAVE ROUNDED CORNERS.
F-9000 SITE EQUIPMENT				
IN-CONTRACT CASEWORK	TYPE OR STYLE refer to DWGS, A-222 for details	O OPEN	P PANEL	6. ALL INTERIOR FINISHES SHALL COMPLY WITH THE REQUIRED CLASSIFICATIONS AS DESCRIBED IN THE FLORIDA FIRE PREVENTION CODE. ALL INTERIOR FINISHES TO BE CLASS "A".
B BASE				
C CABINET				7. PROVIDE ALL NECESSARY BLOCKING AND BACKING AT PARTITIONS ALONG ALL CABINET AREAS AS REQUIRED TO SUSTAIN 75LBS PER LINEAR FEET OF SHELVING/CASEWORK AS PER AMI STANDARDS. SEE SPECIFICATIONS.
D DRAWERS				
E VENTED				
F FULL LENGTH-WALL-WALL				
G DISH CABINET/LINENS				
H SPECIAL OR CUSTOM				
M WALLBOARDS				
N FALSE PANEL				

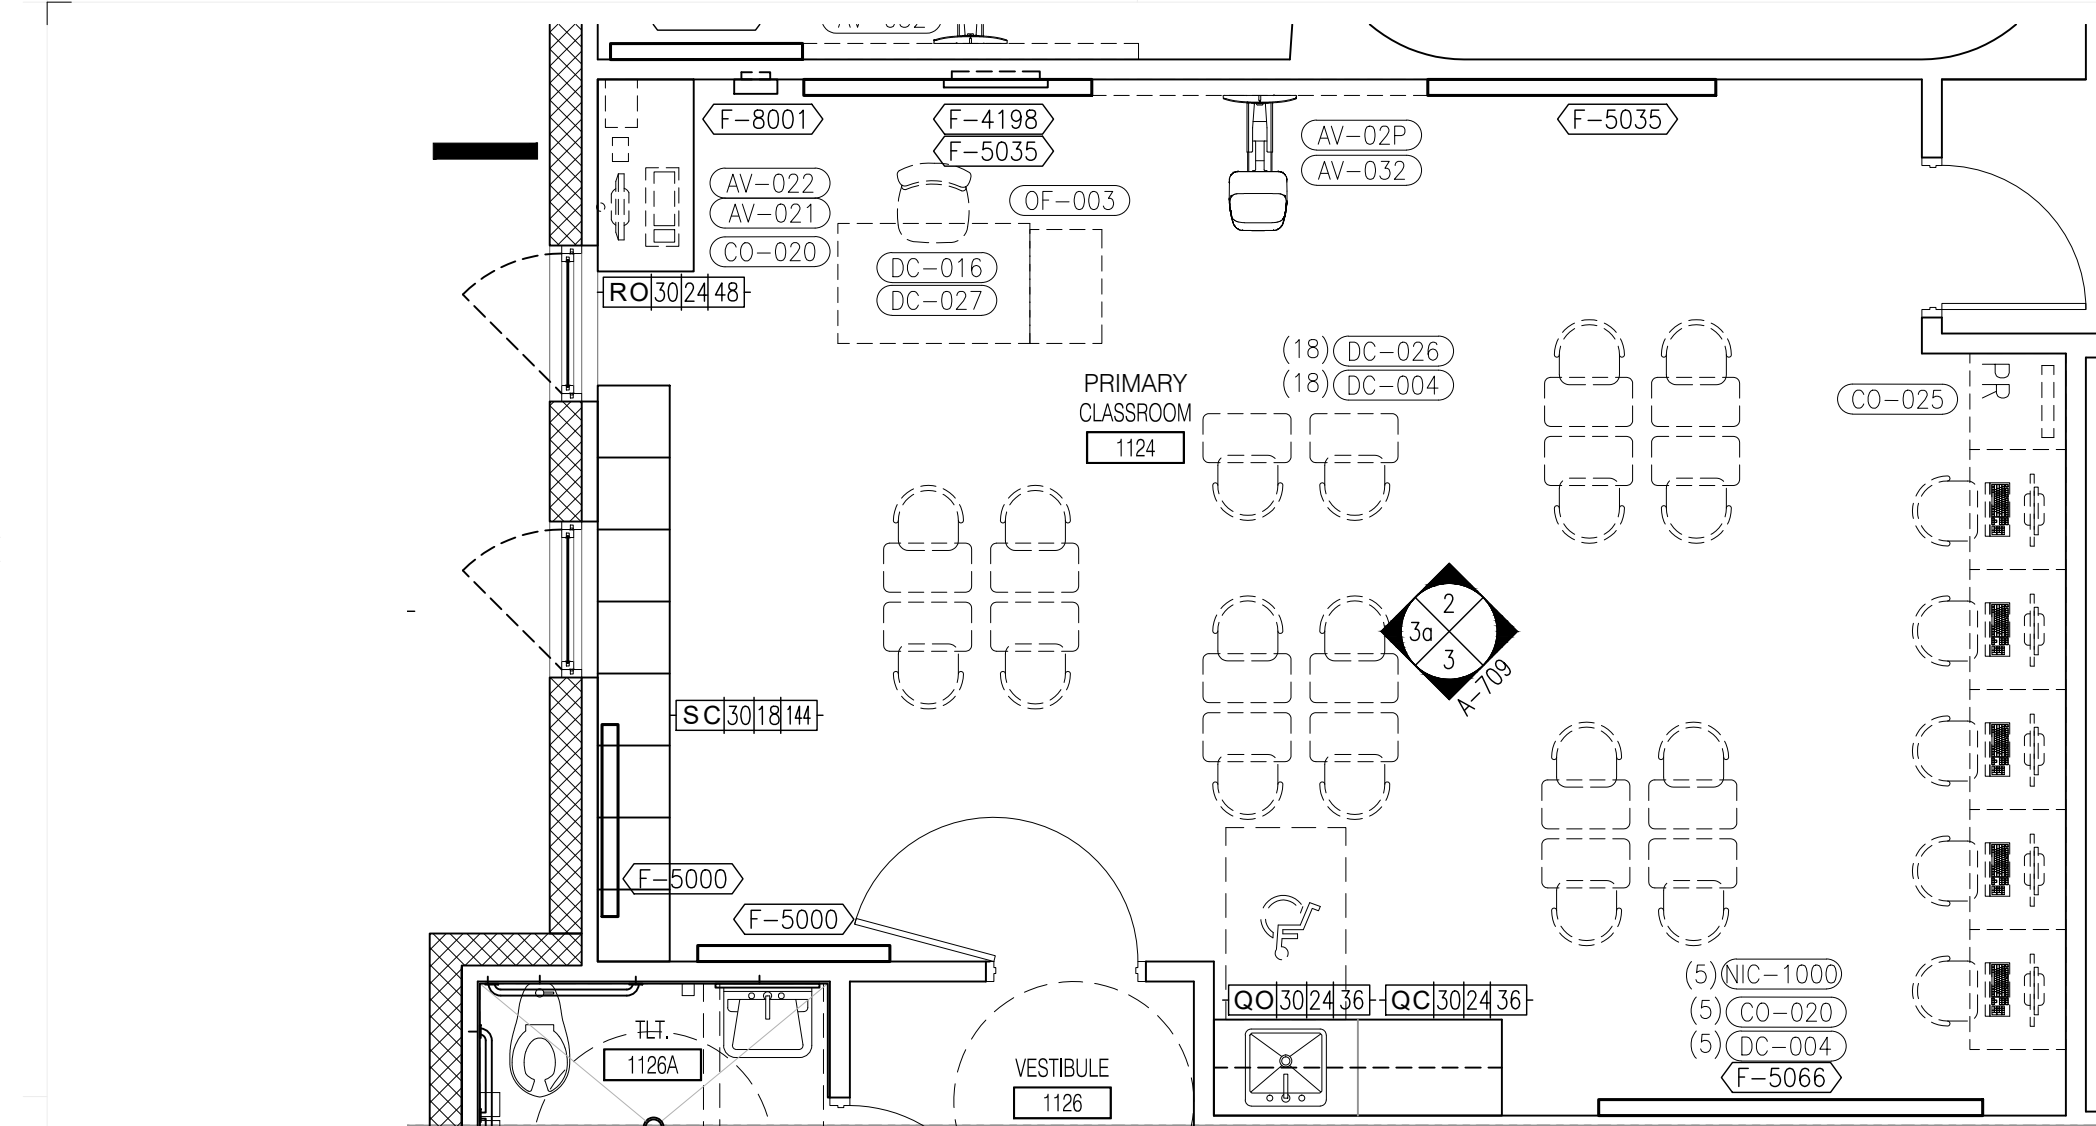

DRAWING TITLE:


**ENL. RESOURCES
RM & TEACHER PL.
PLAN & ELEVATIONS**

SCALE AS NOTED


ISSUE DATE: 12.16.19	PROJECT NO: 1906
-------------------------	---------------------

SHEET:


A-710

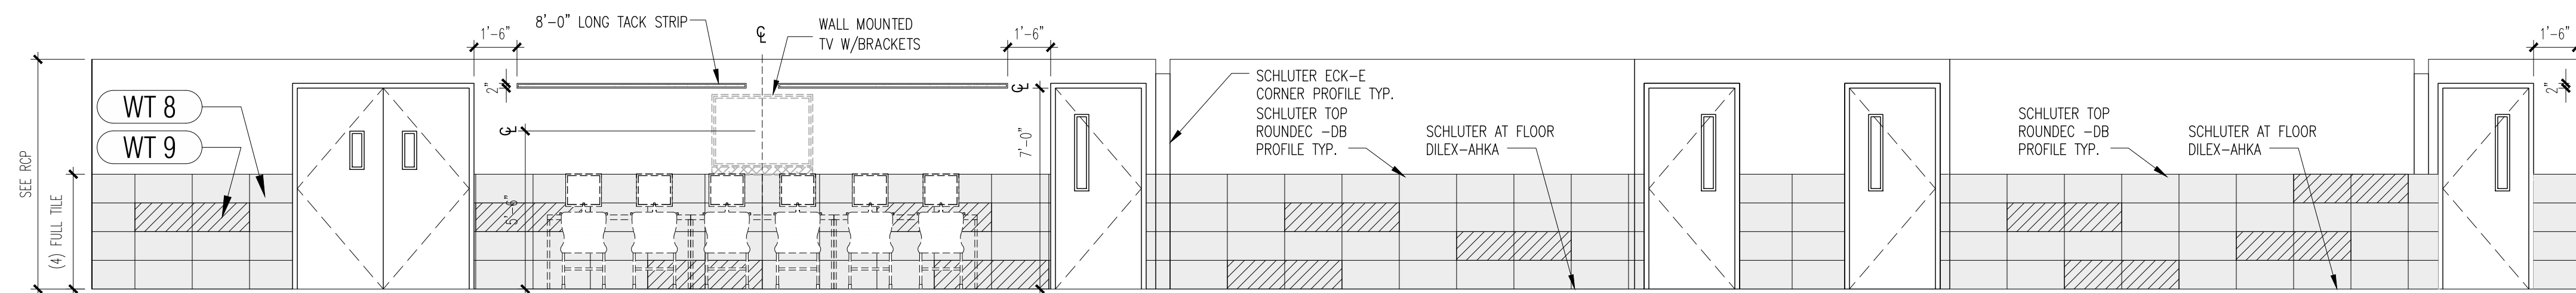


2 ENLARGED TYPICAL EXTENDED LEARNING
A-711 Scale: 1/4" = 1'-0"

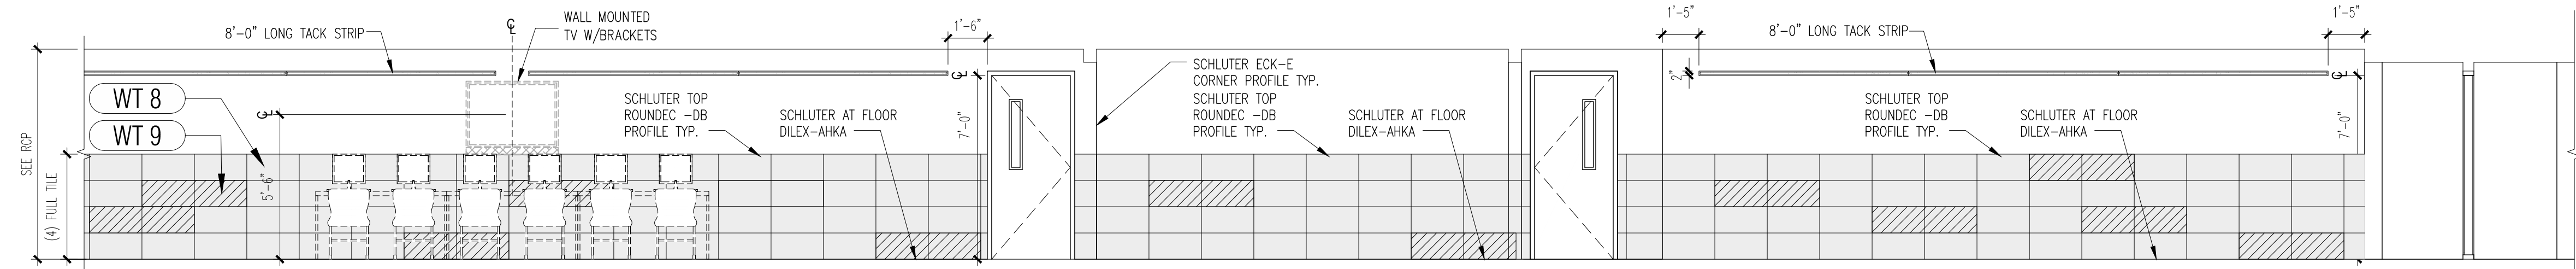


3 ENLARGED TYPICAL EXTENDED LEARNING CONT'D
A-711 Scale: 1/4" = 1'-0"

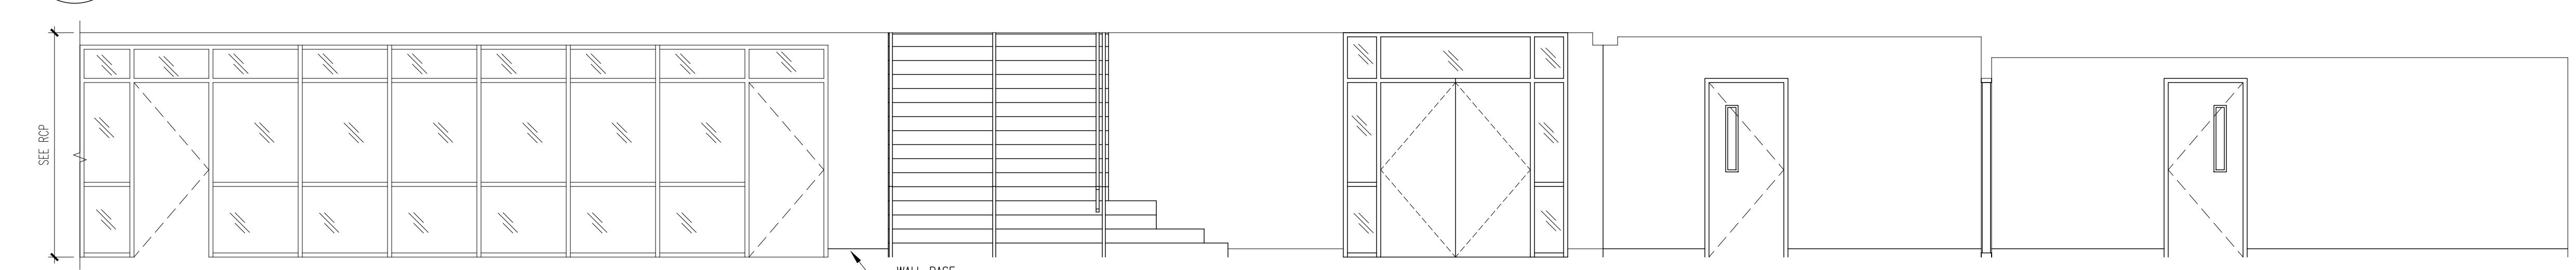


4 ENLARGED TYPICAL EXTENDED LEARNING CONT'D
A-711 Scale: 1/4" = 1'-0"

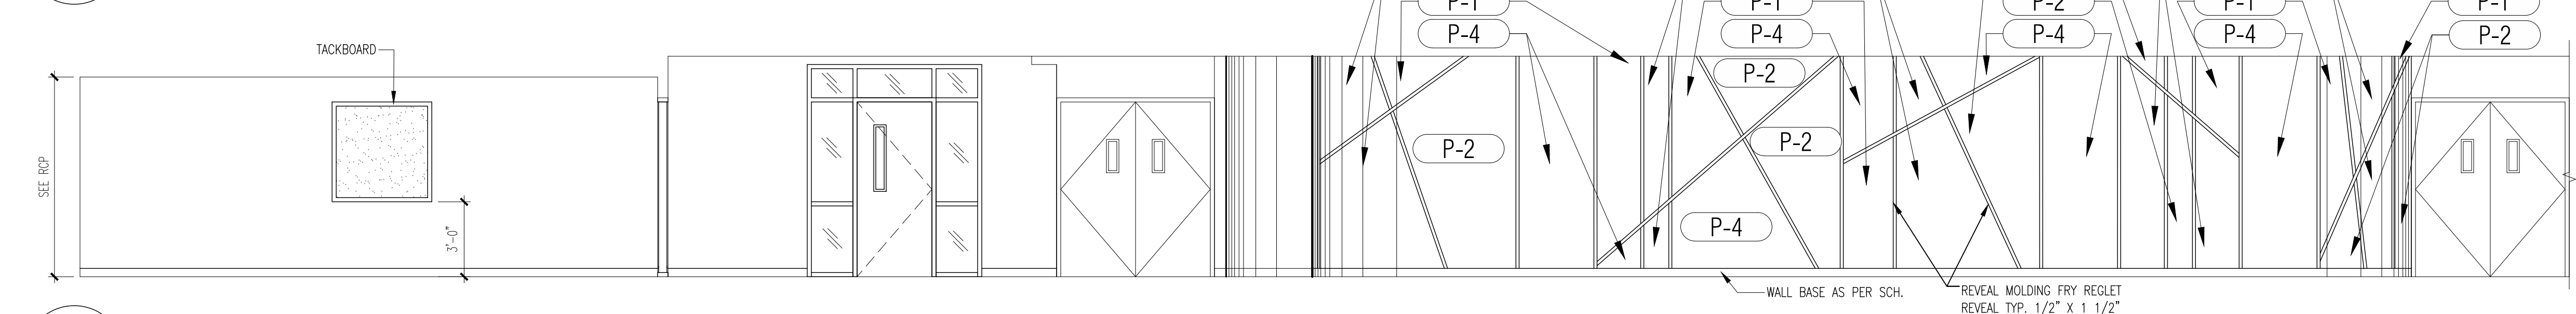


5 ENLARGED TYPICAL EXTENDED LEARNING CONT'D
A-711 Scale: 1/4" = 1'-0"

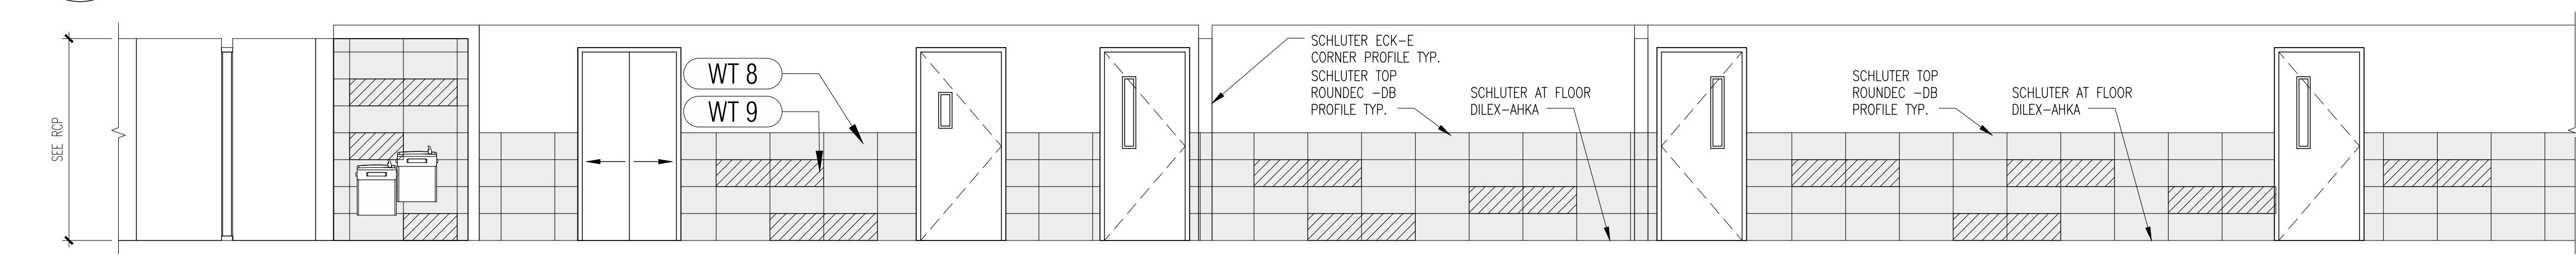


6 ENLARGED TYPICAL EXTENDED LEARNING CONT'D
A-711 Scale: 1/4" = 1'-0"

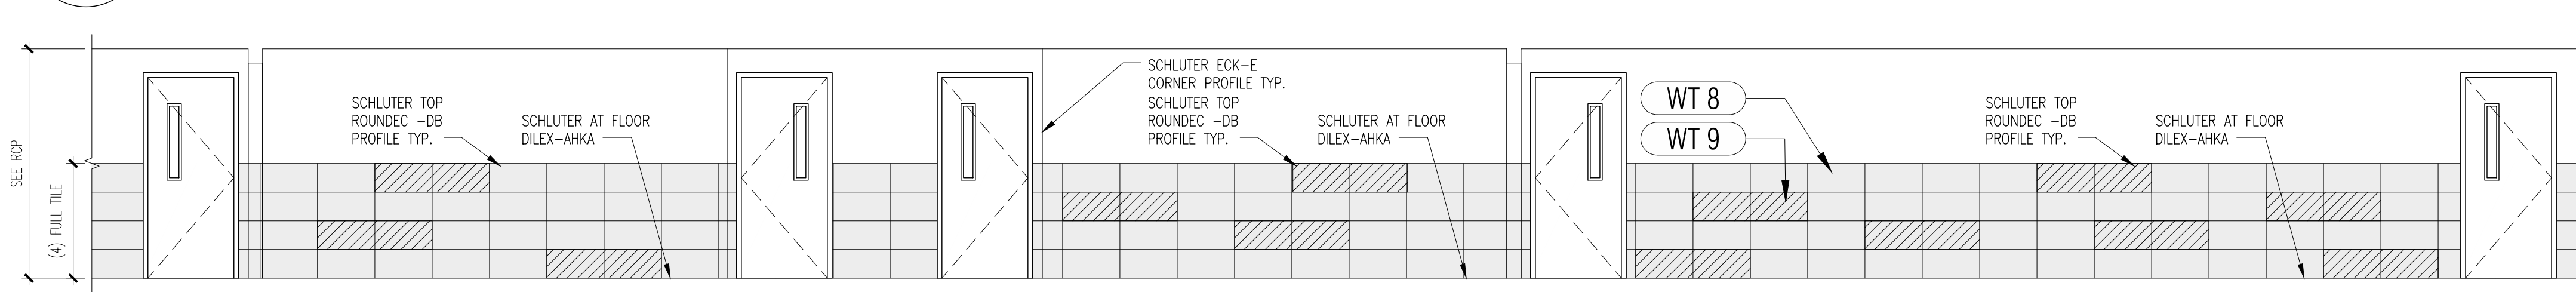

7 ENLARGED TYPICAL EXTENDED LEARNING CONT'D
A-711 Scale: 1/4" = 1'-0"

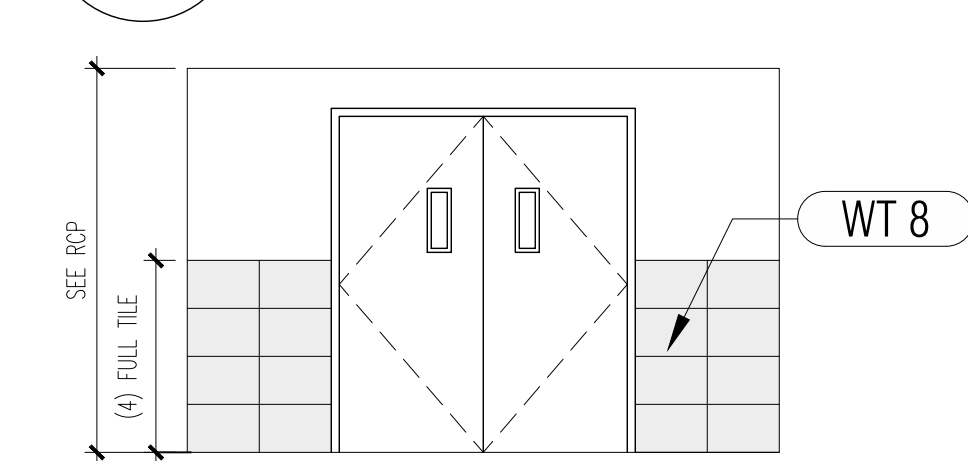

8 EXLARGED TYPICAL EXTENDED LEARNING THRESHOLD
A-711 Scale: 1/4" = 1'-0"

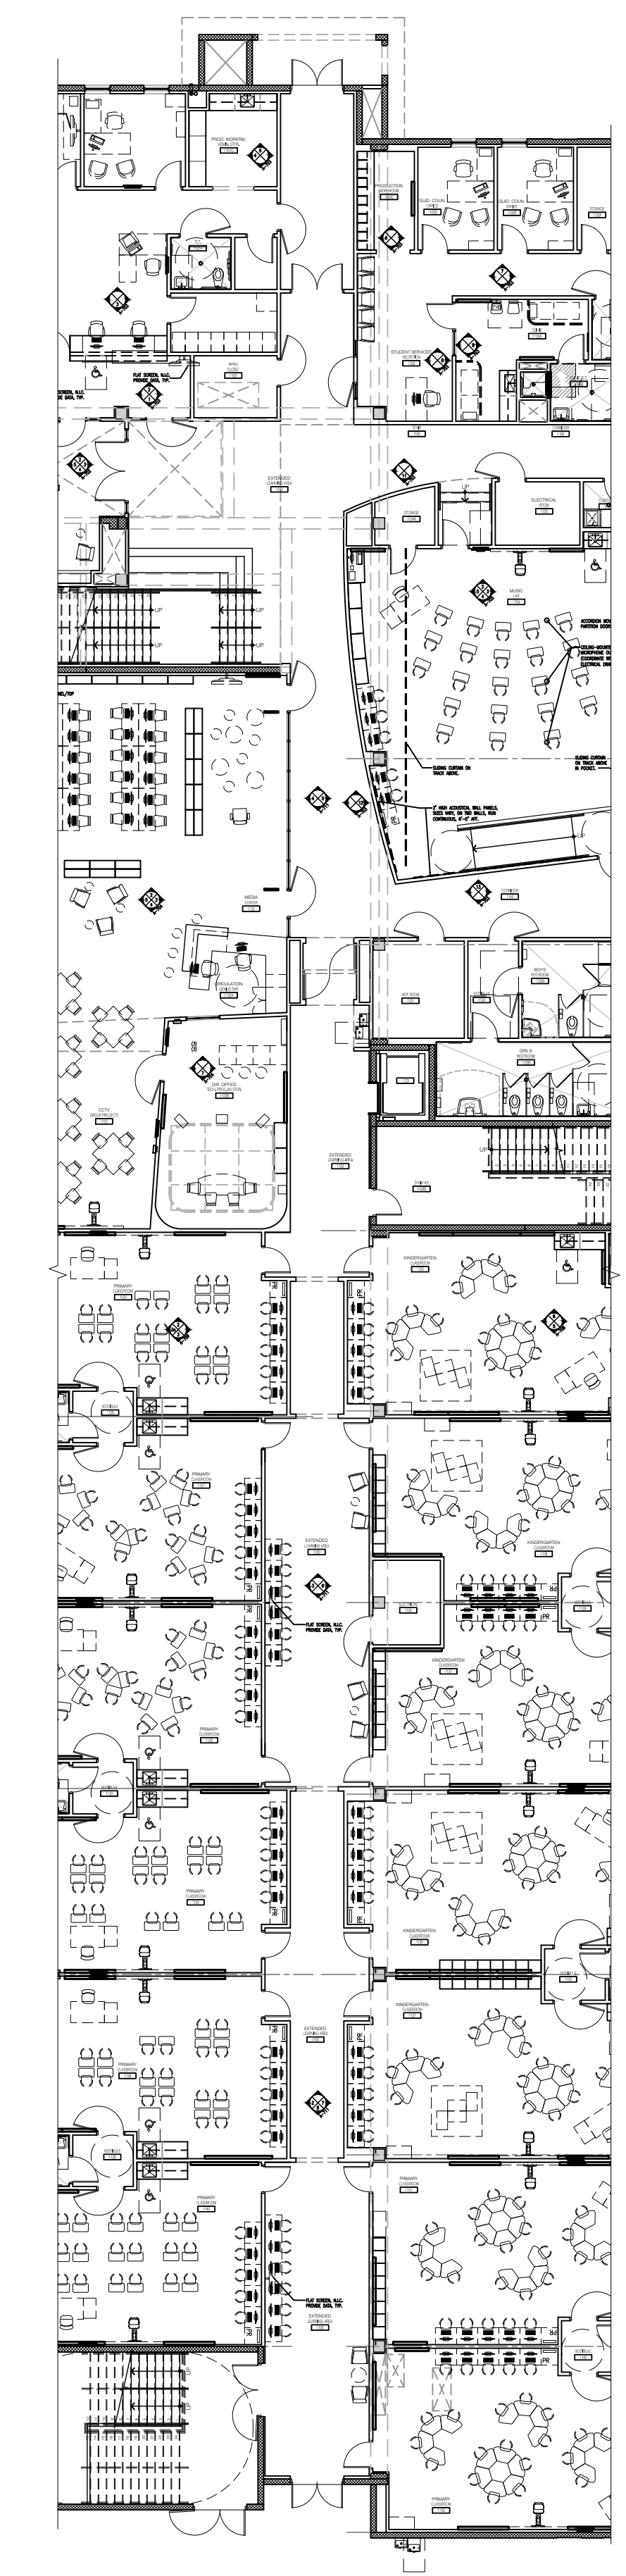


1 ENLARGED TYPICAL EXTENDED LEARNING PLAN
A-711 Scale: 1/16" = 1'-0"

CHECKED BY: LR	DRAWN BY: C.V.
-------------------	-------------------

CONSULTANT INFO:

NEW ELEMENTARY SCHOOL (K-5)
VENETIAN PARC WEST
SOUTHWEST 157th AVENUE and 174th STREET
MIAMI, FL. 33187
MDCPS PROJECT No. 01892600

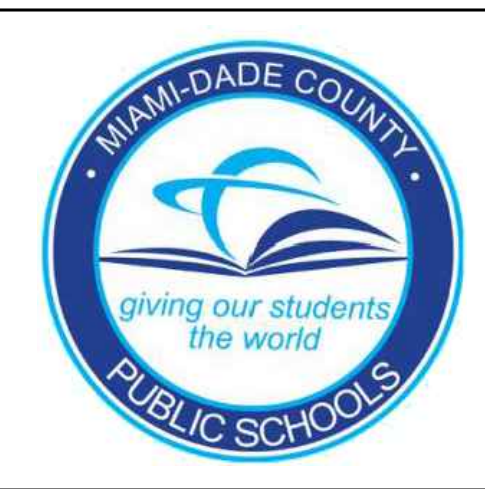

KEY PLAN

CONSULTANT INFO:

RAI


RAI

RAI


RAI

RAI


RAI

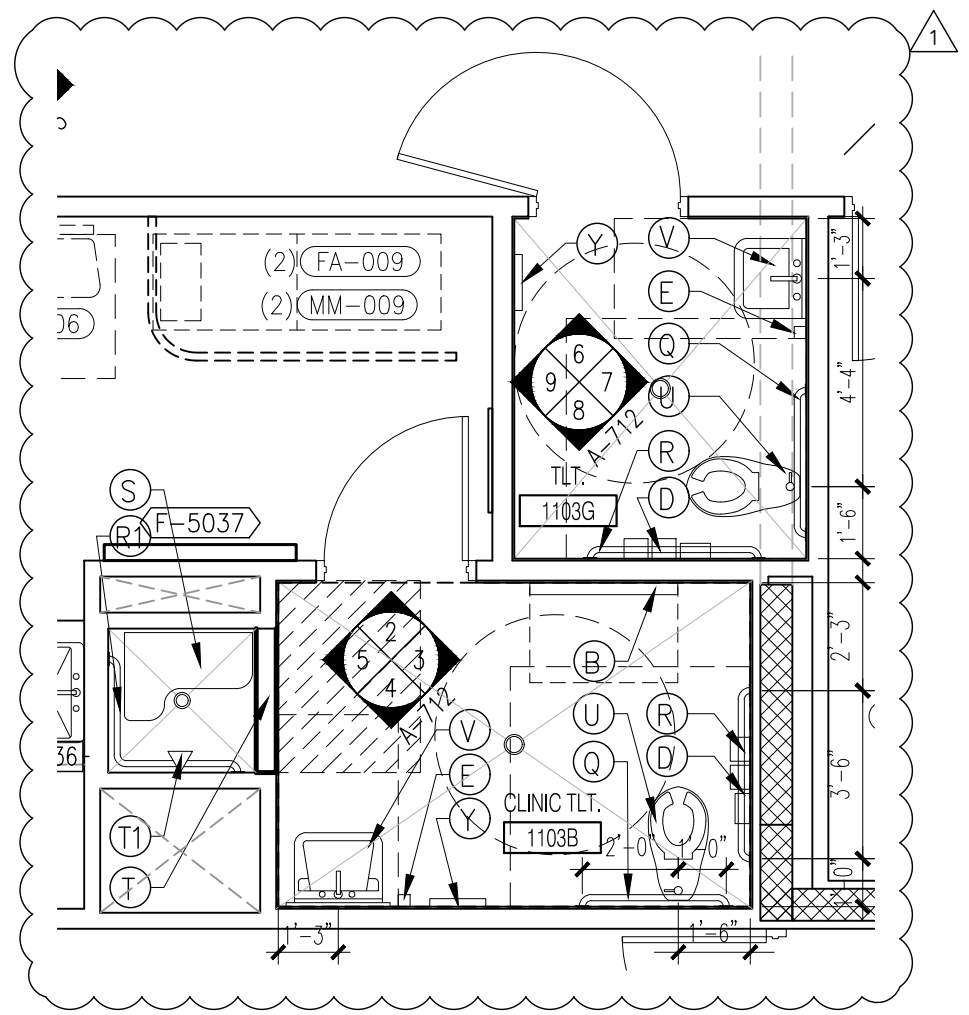


1 **ENLARGED TOILET ROOM PLAN-STAFF/CLINIC**
A-712 Scale: 1/4"= 1'-0"

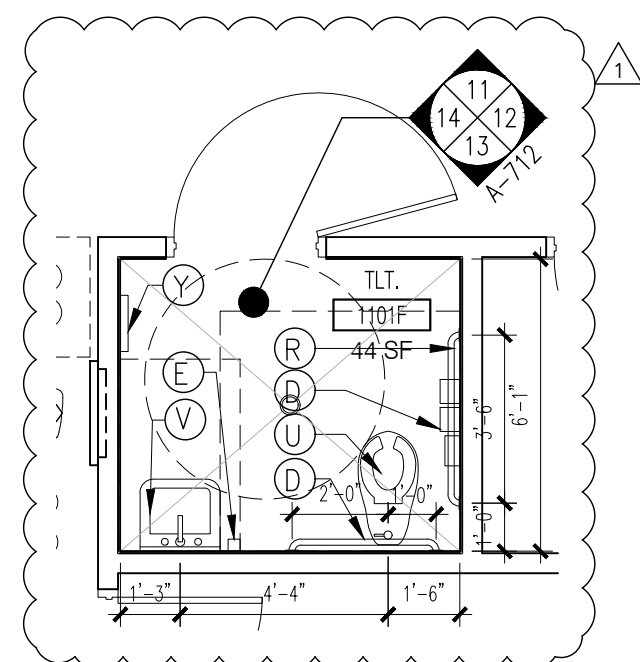


10 **ENLARGED TOILET ROOM PLAN-STAFF/ADMIN**
A-712 Scale: 1/4"= 1'-0"

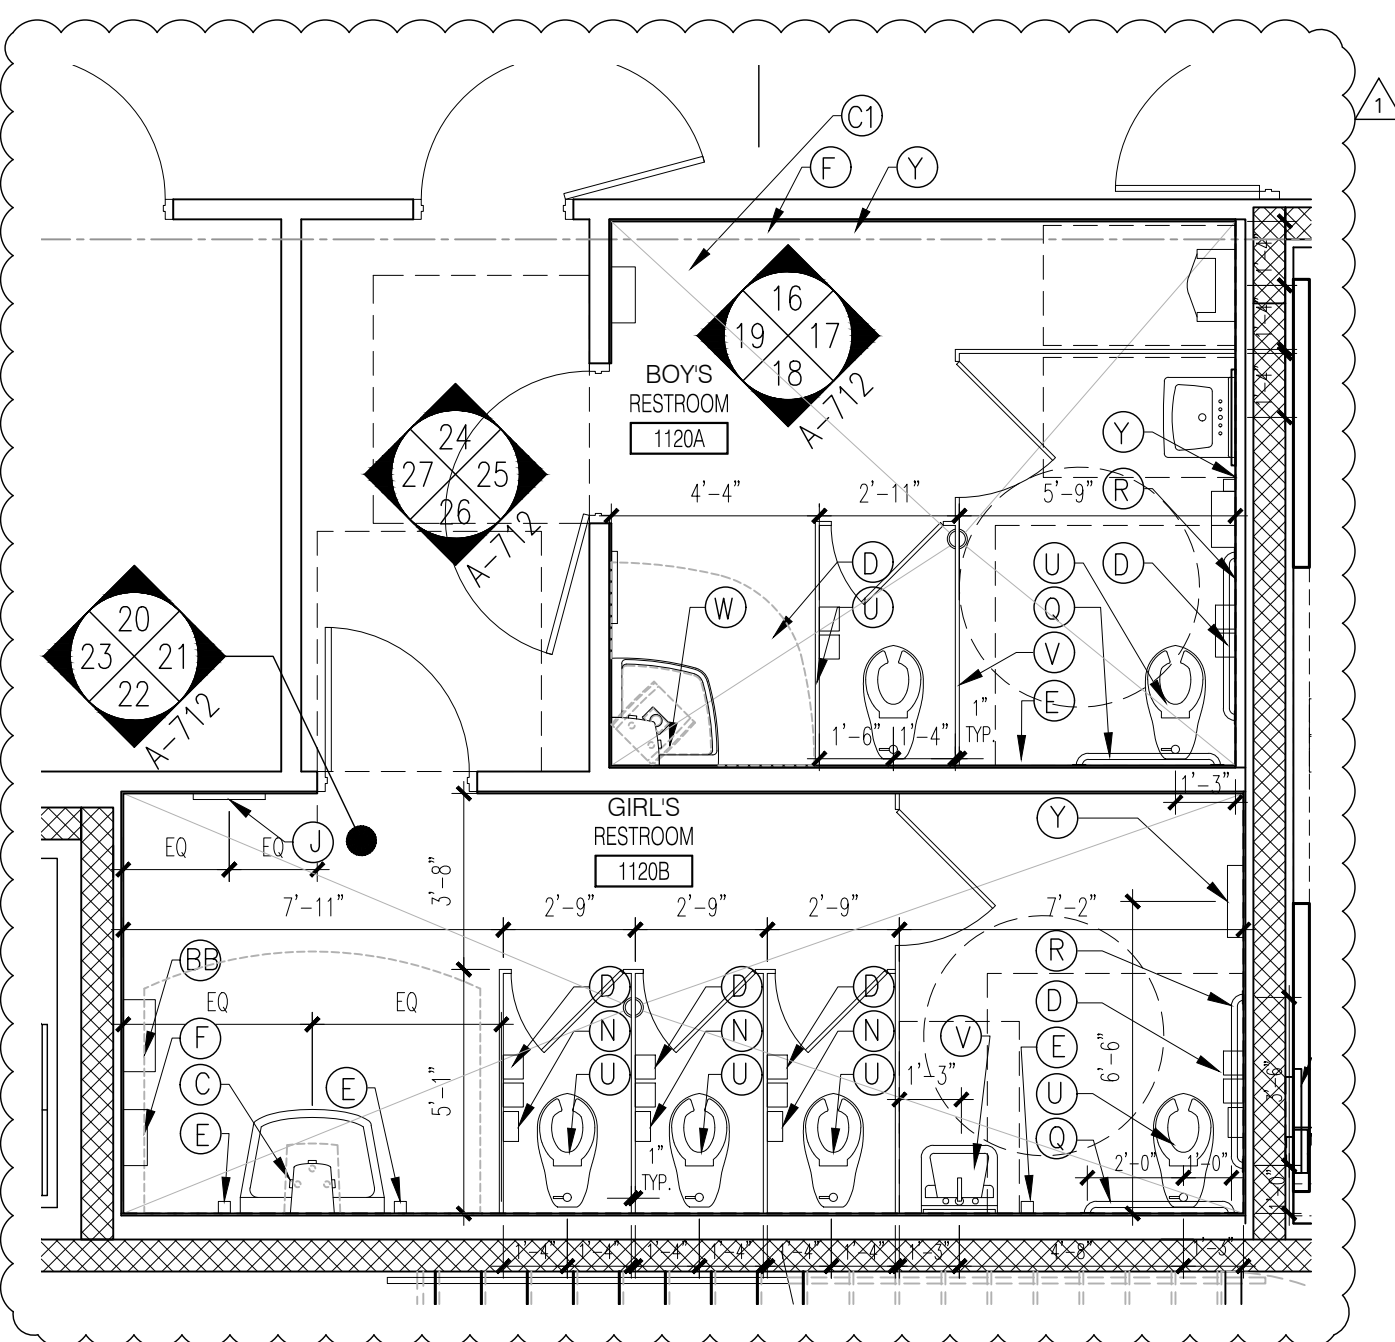


15 **ENLARGED GROUP TOILET ROOM PLAN**
A-712 Scale: 1/4"= 1'-0"

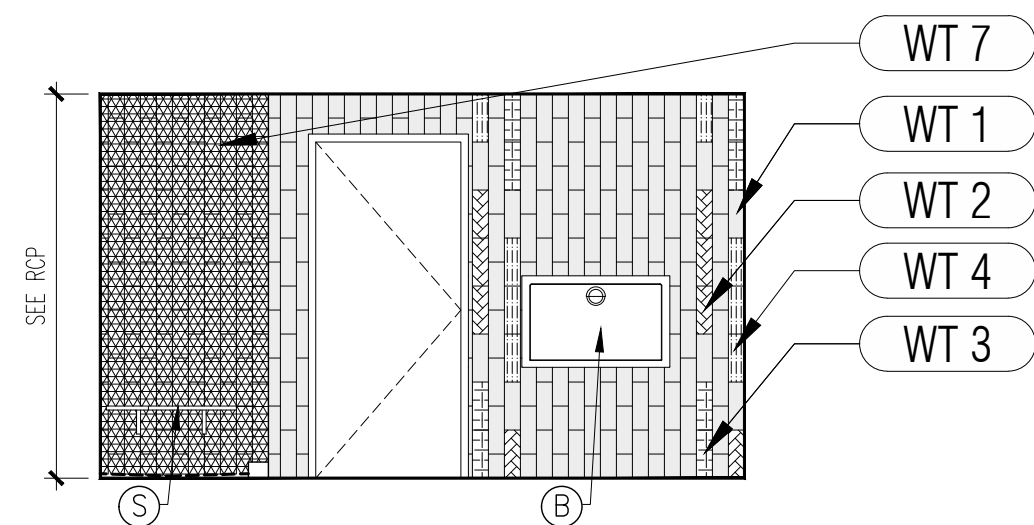


2 **CLINIC SHOWER ELEVATION**
A-712 Scale: 1/4"= 1'-0"

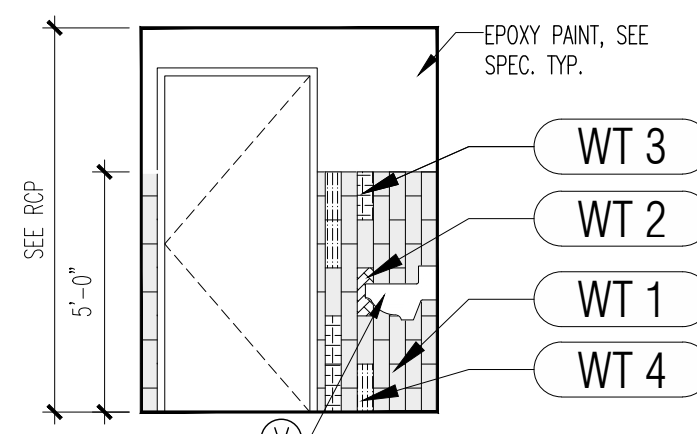


6 **STAFF TOILET ELEVATION**
A-712 Scale: 1/4"= 1'-0"

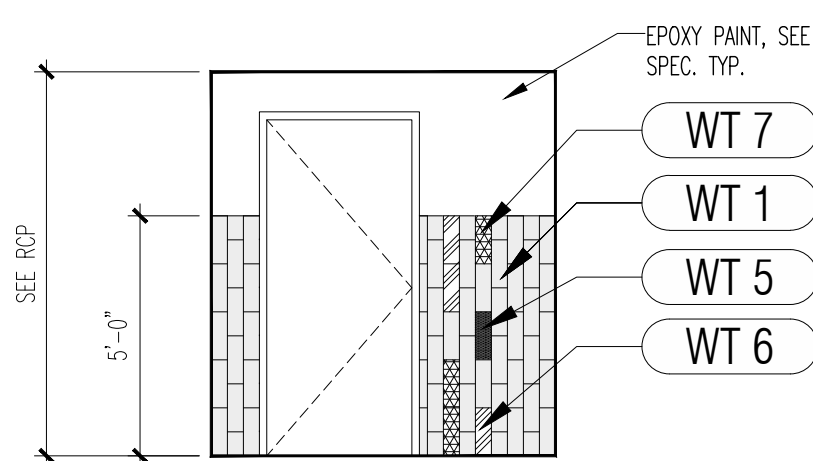


11 **STAFF/ADMIN TOILET ELEVATION**
A-712 Scale: 1/4"= 1'-0"

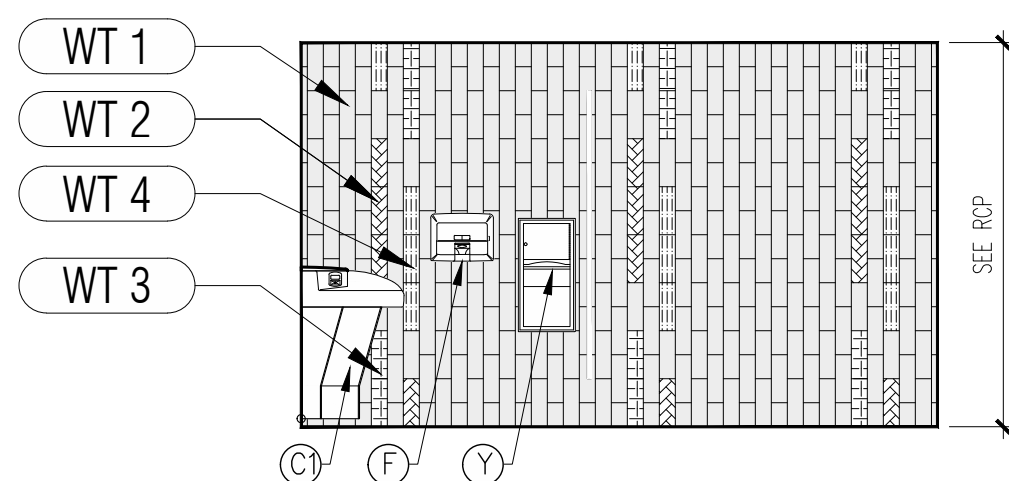


16 **BOY'S RESTROOM ELEVATION**
A-712 Scale: 1/4"= 1'-0"

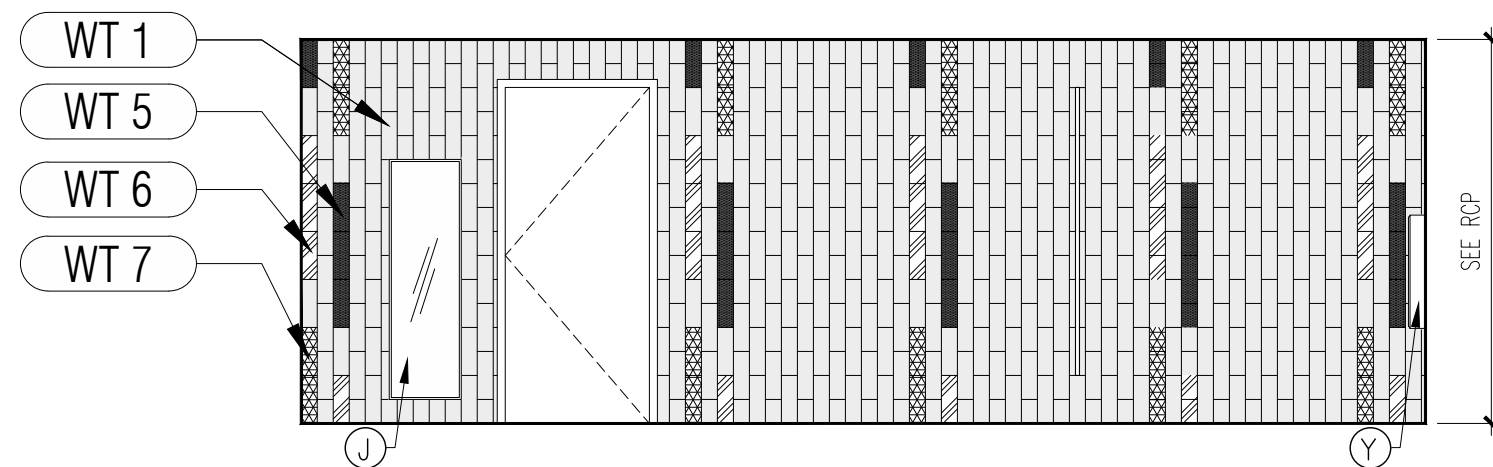


20 **GIRL'S RESTROOM ELEVATION**
A-712 Scale: 1/4"= 1'-0"

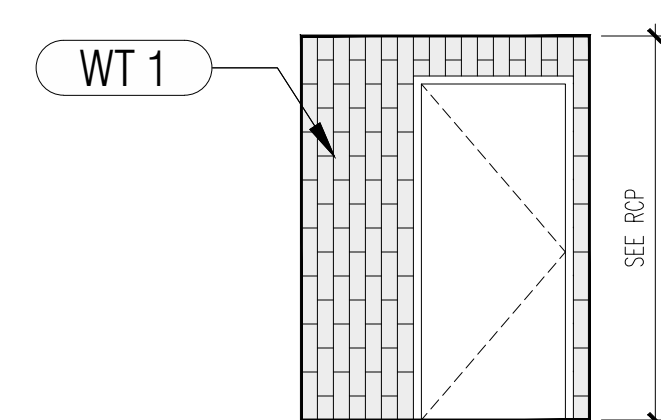


24 **VESTIBULE ELEVATION**
A-712 Scale: 1/4"= 1'-0"

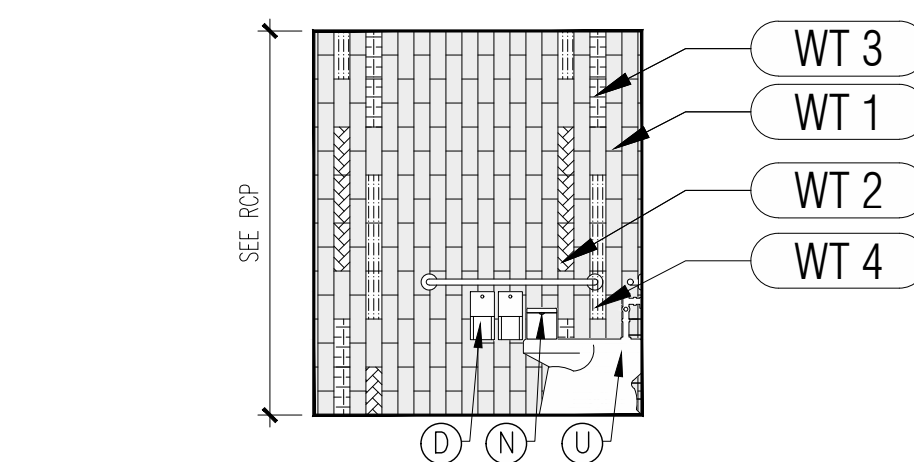


3 **CLINIC SHOWER ELEVATION**
A-712 Scale: 1/4"= 1'-0"

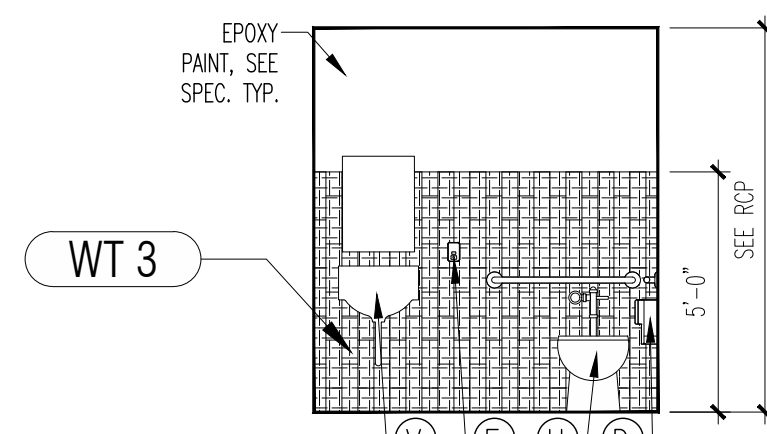


7 **STAFF TOILET ELEVATION**
A-712 Scale: 1/4"= 1'-0"

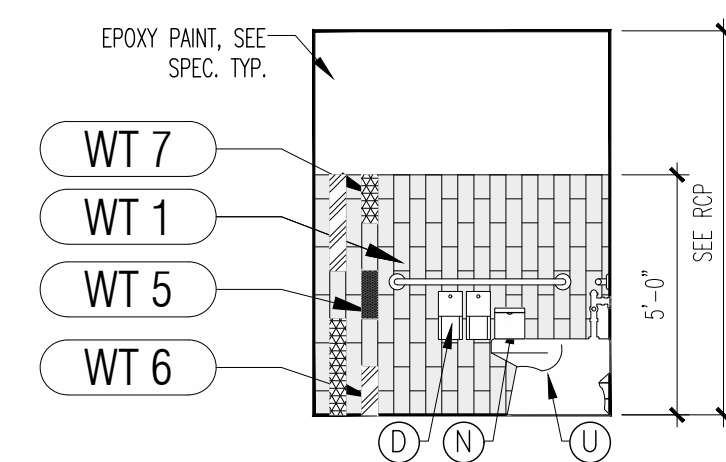


12 **STAFF/ADMIN TOILET ELEVATION**
A-712 Scale: 1/4"= 1'-0"

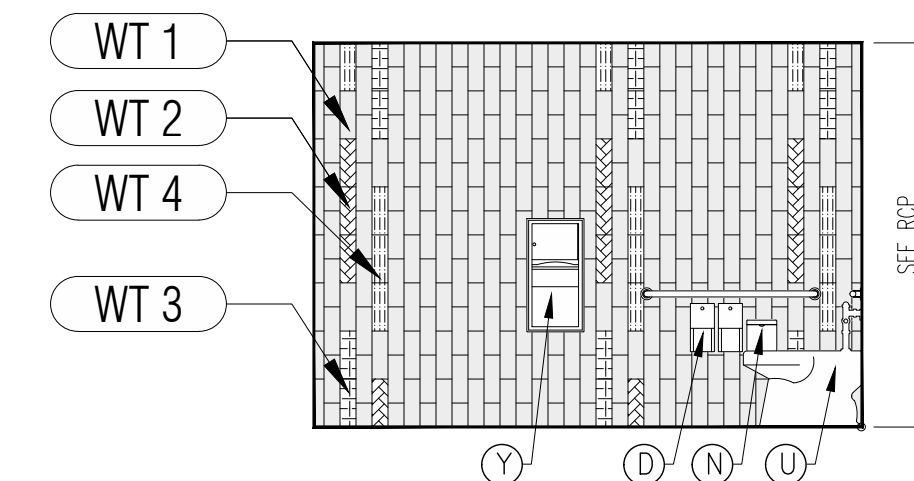


17 **BOY'S RESTROOM ELEVATION**
A-712 Scale: 1/4"= 1'-0"

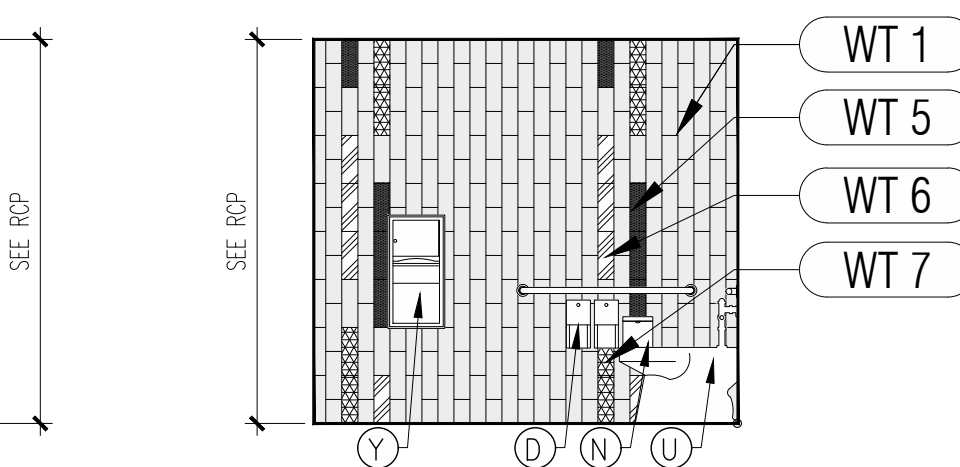


21 **GIRL'S RESTROOM ELEVATION**
A-712 Scale: 1/4"= 1'-0"

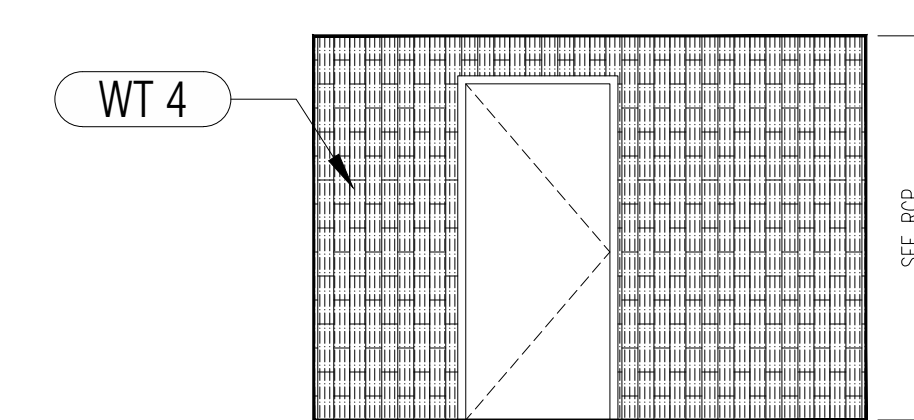


25 **VESTIBULE ELEVATION**
A-712 Scale: 1/4"= 1'-0"

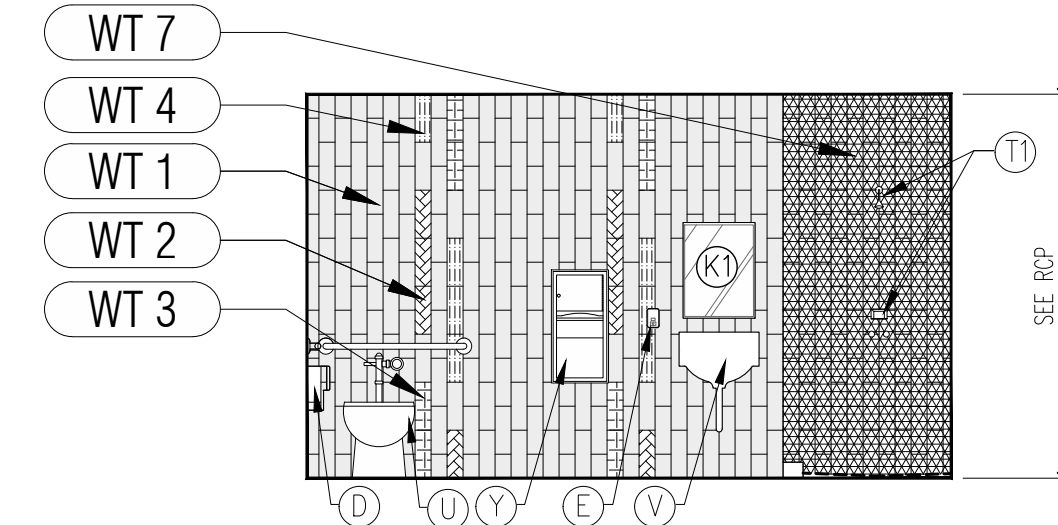


4 **CLINIC SHOWER ELEVATION**
A-712 Scale: 1/4"= 1'-0"

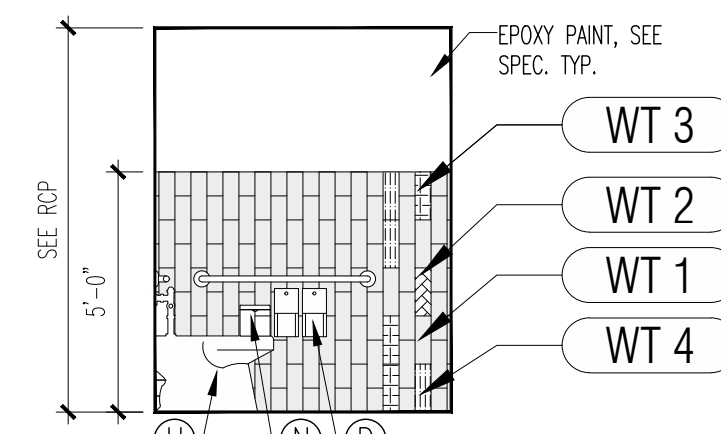


8 **STAFF TOILET ELEVATION**
A-712 Scale: 1/4"= 1'-0"

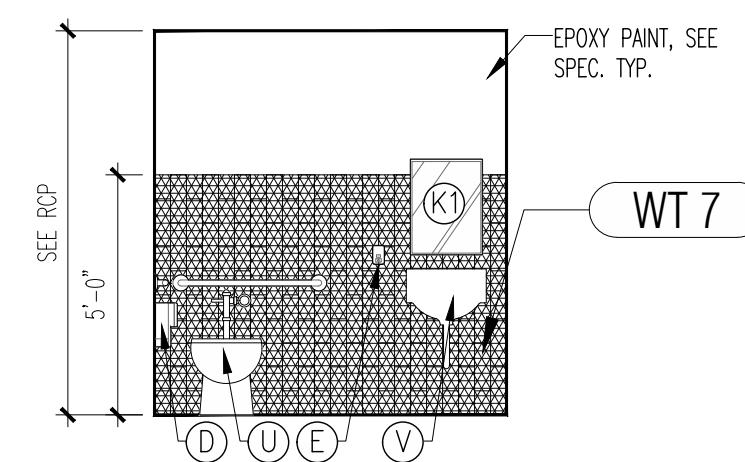


13 **STAFF/ADMIN TOILET ELEVATION**
A-712 Scale: 1/4"= 1'-0"

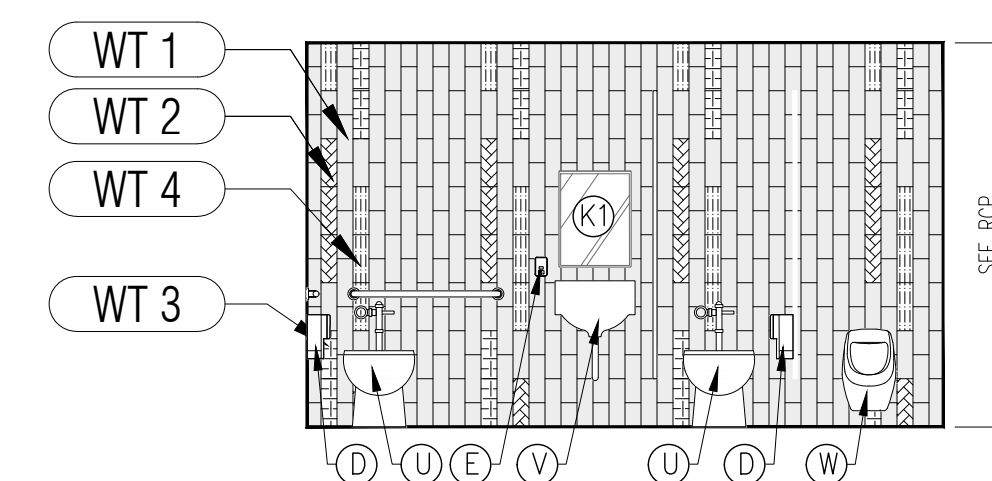


18 **BOY'S RESTROOM ELEVATION**
A-712 Scale: 1/4"= 1'-0"

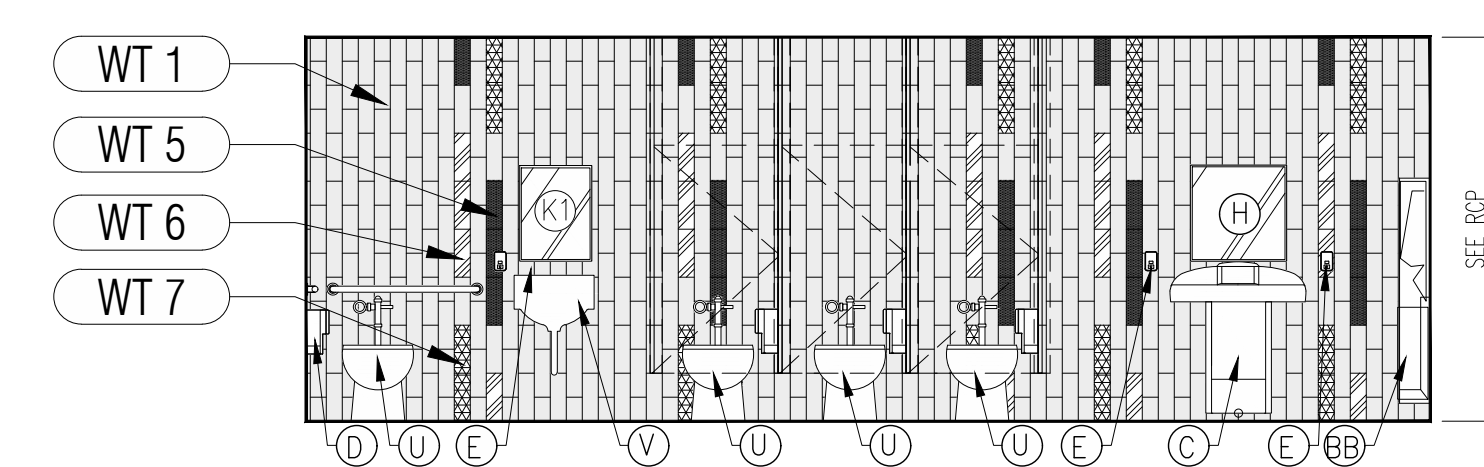


22 **GIRL'S RESTROOM ELEVATION**
A-712 Scale: 1/4"= 1'-0"

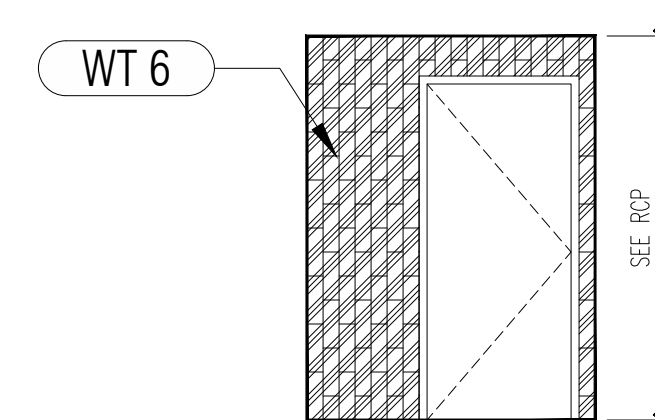


26 **VESTIBULE ELEVATION**
A-712 Scale: 1/4"= 1'-0"

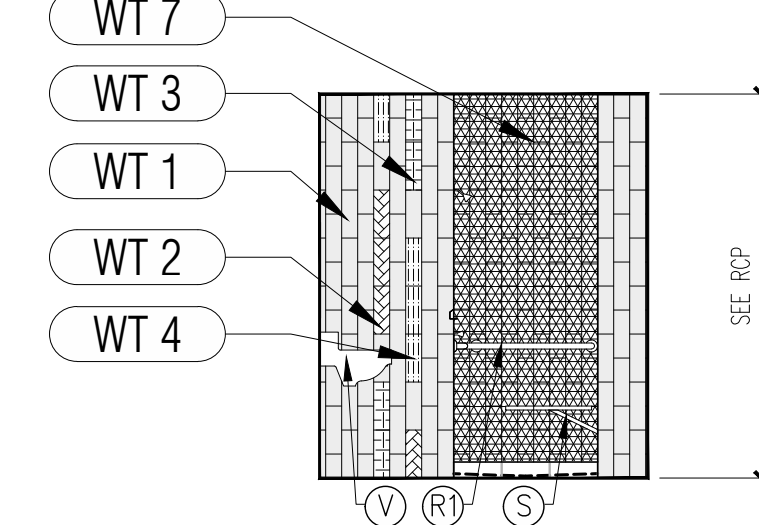


5 **CLINIC SHOWER ELEVATION**
A-712 Scale: 1/4"= 1'-0"

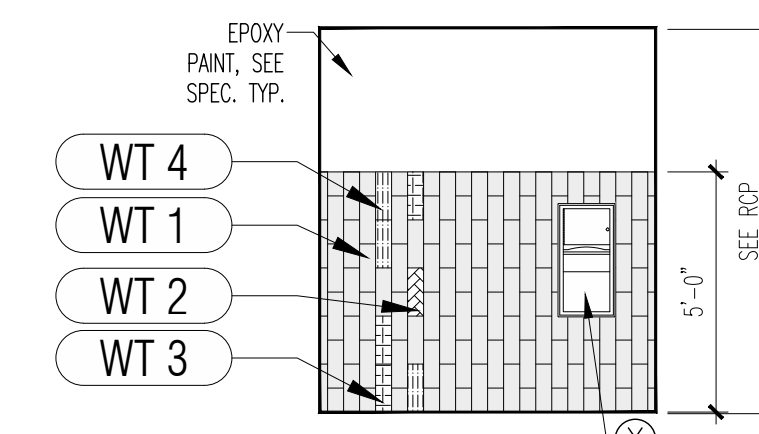


9 **STAFF TOILET ELEVATION**
A-712 Scale: 1/4"= 1'-0"

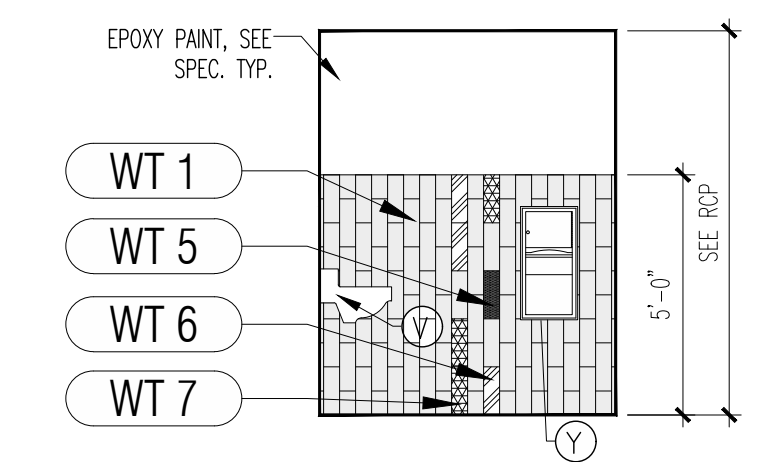


14 **STAFF/ADMIN TOILET ELEVATION**
A-712 Scale: 1/4"= 1'-0"

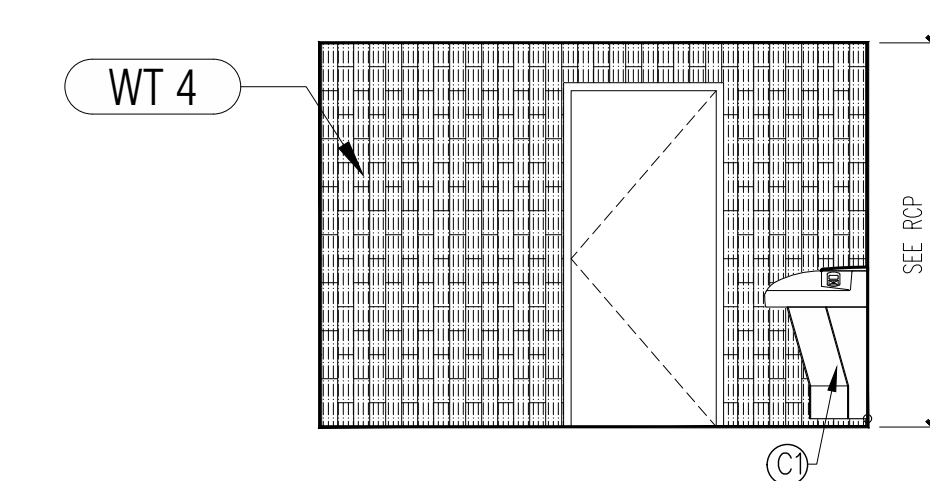

19 **BOY'S RESTROOM ELEVATION**
A-712 Scale: 1/4"= 1'-0"

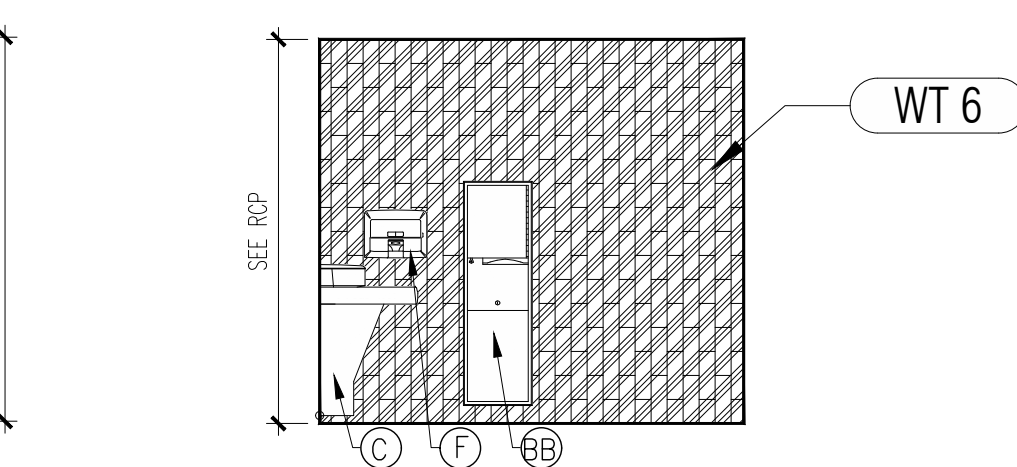


23 **GIRL'S RESTROOM ELEVATION**
A-712 Scale: 1/4"= 1'-0"

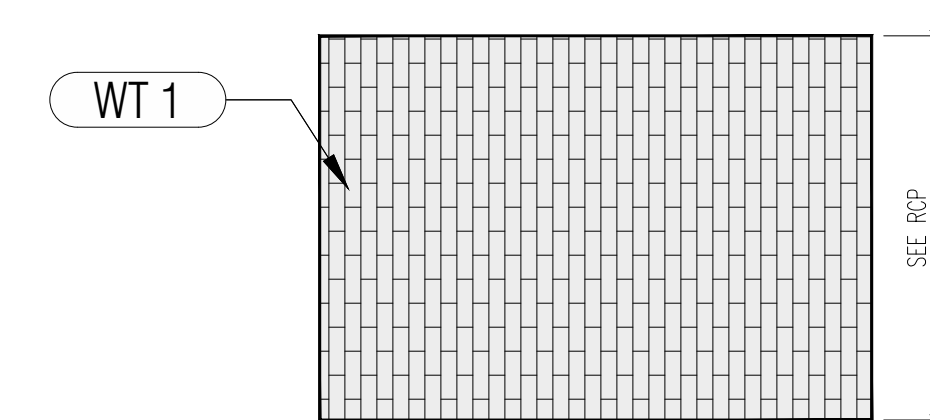

27 **VESTIBULE ELEVATION**
A-712 Scale: 1/4"= 1'-0"


CHECKED BY: LR. DRAWN BY: CV.

CONSULTANT INFO:

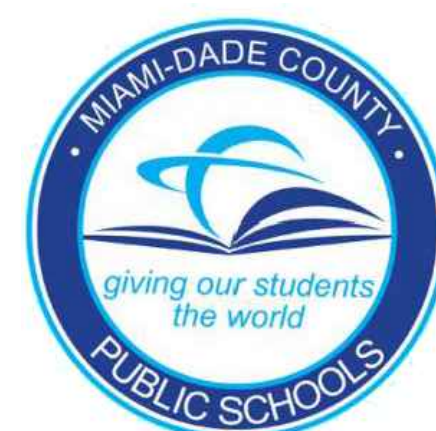

NEW ELEMENTARY SCHOOL (K-5)
VENETIAN PARC WEST
SOUTHWEST 157th AVENUE and 174th STREET
MIAMI, FL. 33187
MDCPS PROJECT No. 01892600

KEY PLAN

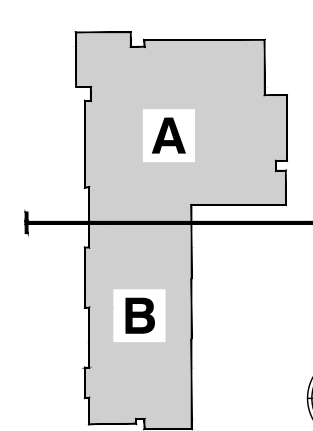

CONSULTANT INFO:

RODRIGUEZ ARCHITECTS, INC.
2121 PONCE DE LEON BLVD., STE. 1010
CORAL GABLES, FL. 33134
TEL: (305) 448-3373
FAX: (305) 448-3374

RODRIGUEZ ARCHITECTS INCORPORATED
2121 PONCE DE LEON BLVD., STE. 1010
CORAL GABLES, FL. 33134
TEL: (305) 448-3373
FAX: (305) 448-3374
A A C — 0 0 1 9 3 3



REVISIONS:


02/14/2020 BUILDING DEPARTMENT COMMENTS

DRAWING TITLE:


ENLARGED TOILET PLANS & ELEVATIONS

SCALE AS NOTED
ISSUE DATE: 12/16/19 PROJECT NO: 1906
SHEET:


A-712

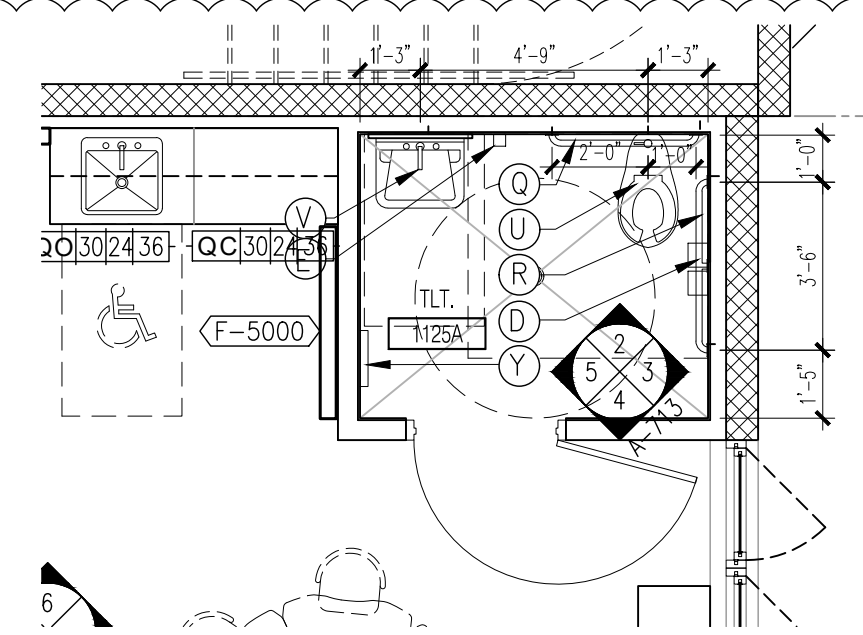


1 ENLARGED TOILET ROOM PLAN-KINDERGARTEN
A-713 Scale: 1/4"= 1'-0"

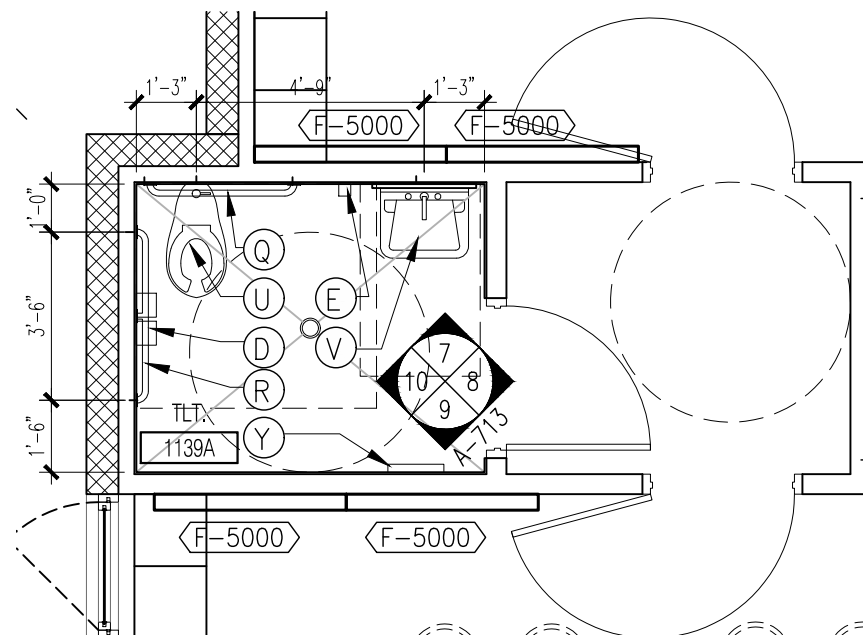


6 ENLARGED TOILET ROOM PLAN-PRIMARY
A-713 Scale: 1/4"= 1'-0"

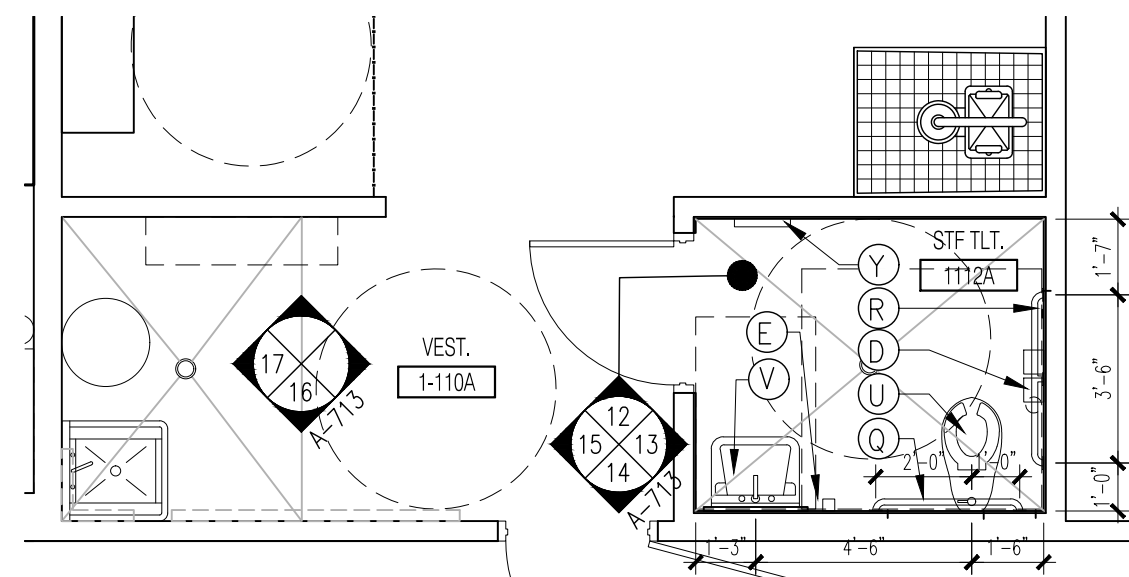


11 ENLARGED TOILET ROOM PLAN-STAFF/CUSTODIAL
A-713 Scale: 1/4"= 1'-0"

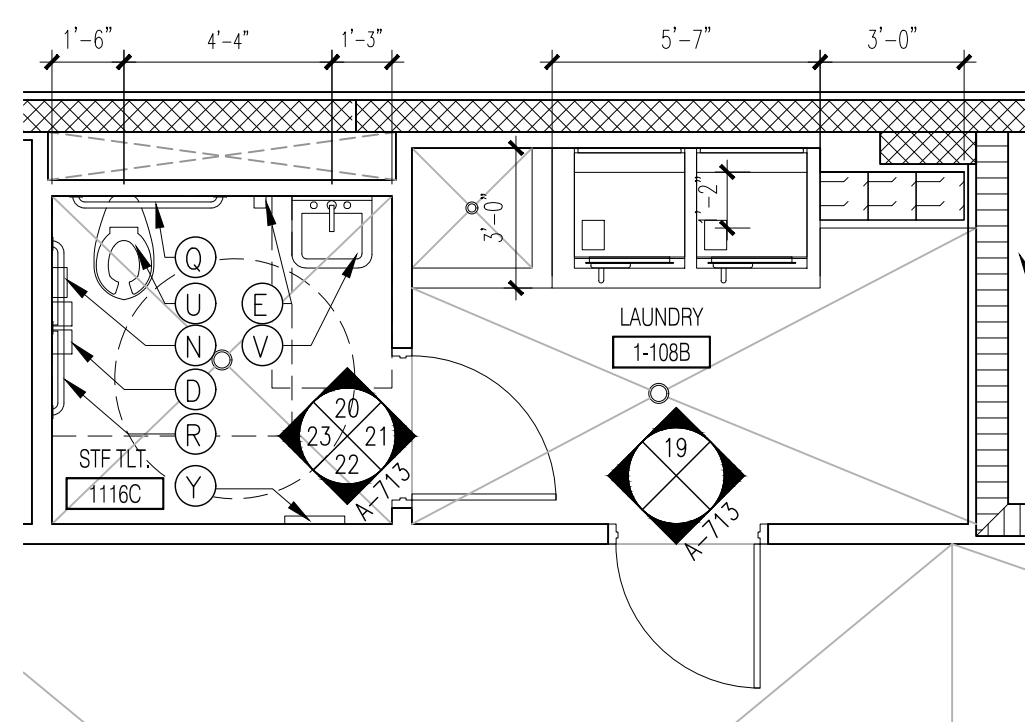


18 ENLARGED TOILET ROOM PLAN-STAFF/LAUNDRY
A-713 Scale: 1/4"= 1'-0"

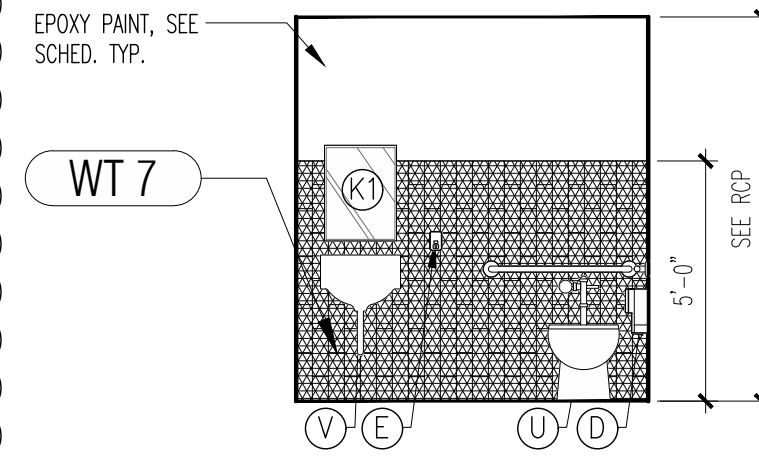


2 KINDERGARTEN TOILET ELEVATION
A-713 Scale: 1/4"= 1'-0"

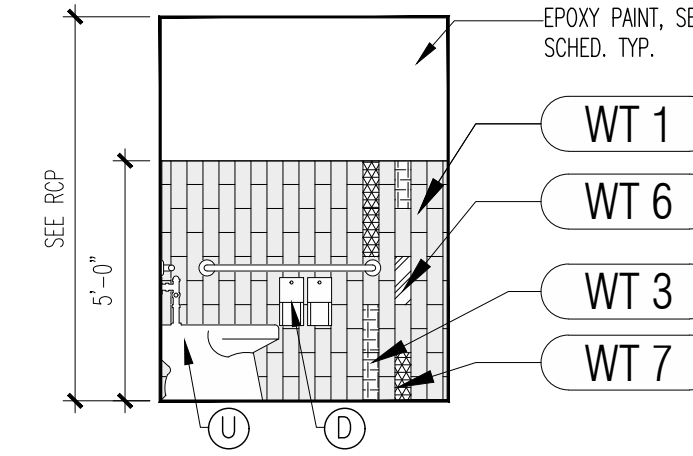


3 KINDERGARTEN TOILET ELEVATION
A-713 Scale: 1/4"= 1'-0"

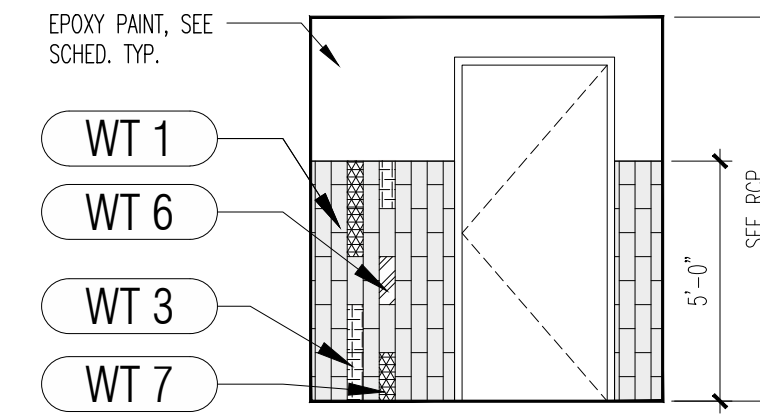


4 KINDERGARTEN TOILET ELEVATION
A-713 Scale: 1/4"= 1'-0"

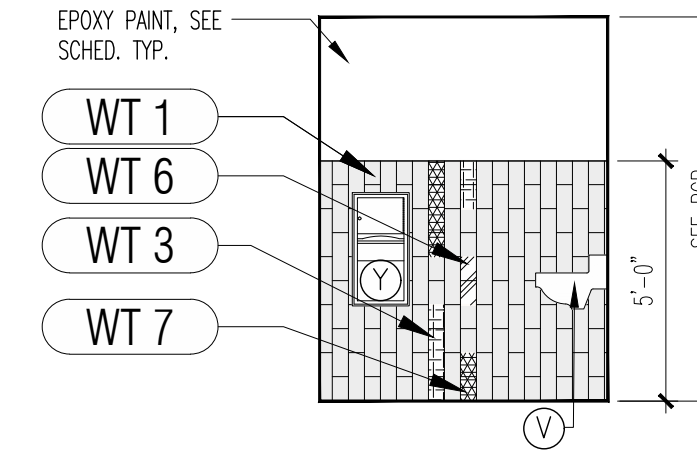


5 KINDERGARTEN TOILET ELEVATION
A-713 Scale: 1/4"= 1'-0"

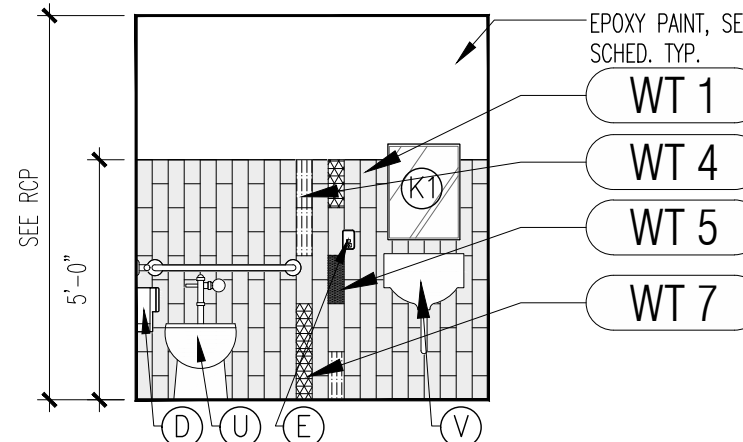


7 PRIMARY TOILET ELEVATION
A-713 Scale: 1/4"= 1'-0"

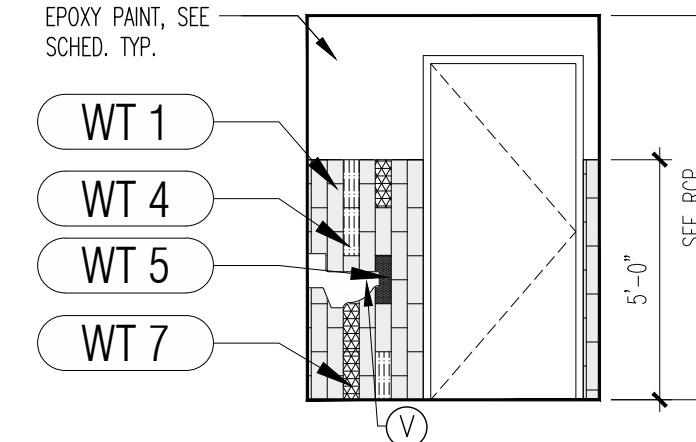


8 PRIMARY TOILET ELEVATION
A-713 Scale: 1/4"= 1'-0"

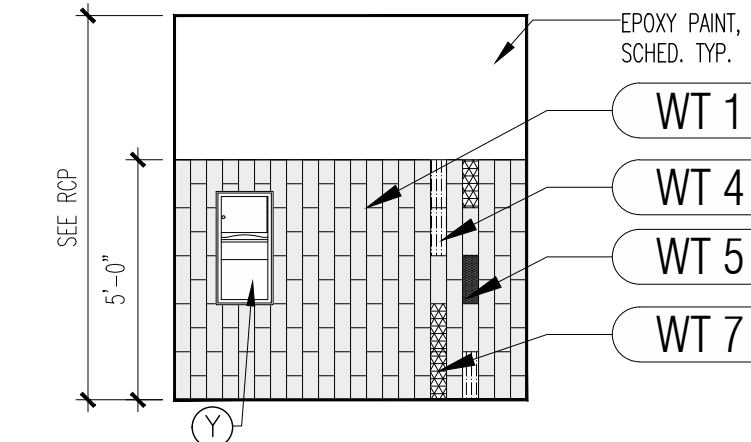


9 PRIMARY TOILET ELEVATION
A-713 Scale: 1/4"= 1'-0"

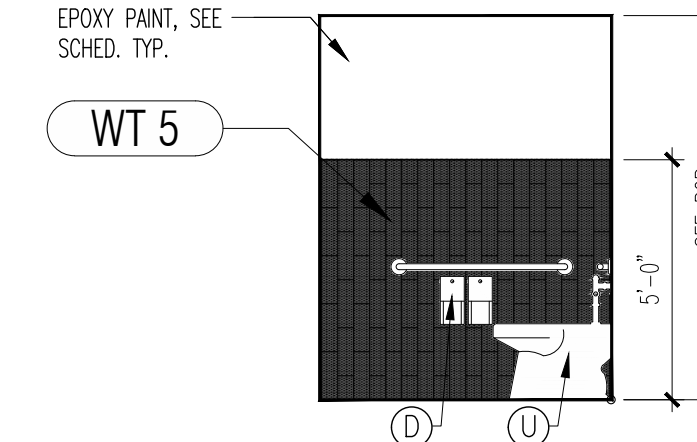


10 PRIMARY TOILET ELEVATION
A-713 Scale: 1/4"= 1'-0"

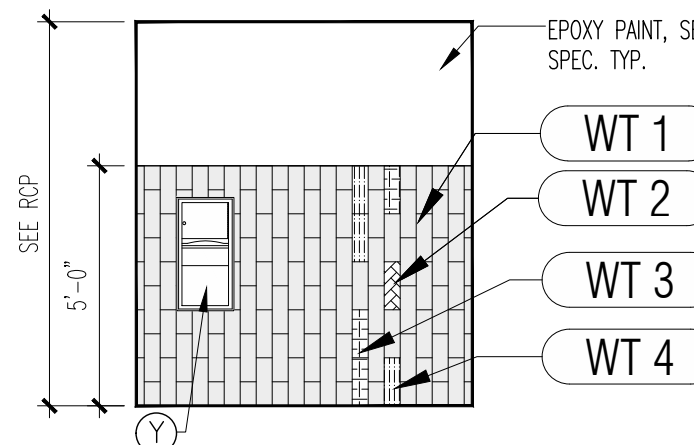


12 STAFF TOILET ELEVATION
A-713 Scale: 1/4"= 1'-0"

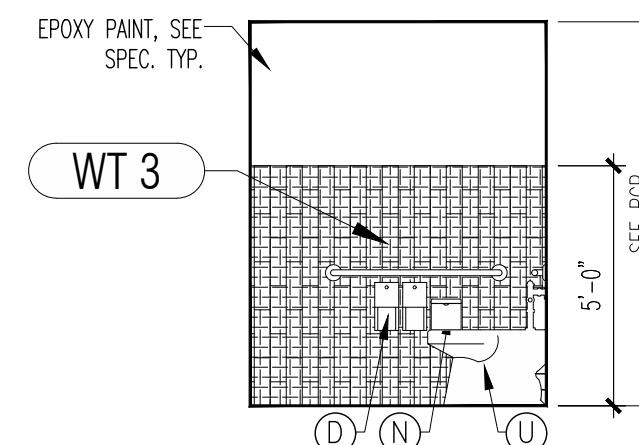


13 STAFF TOILET ELEVATION
A-713 Scale: 1/4"= 1'-0"

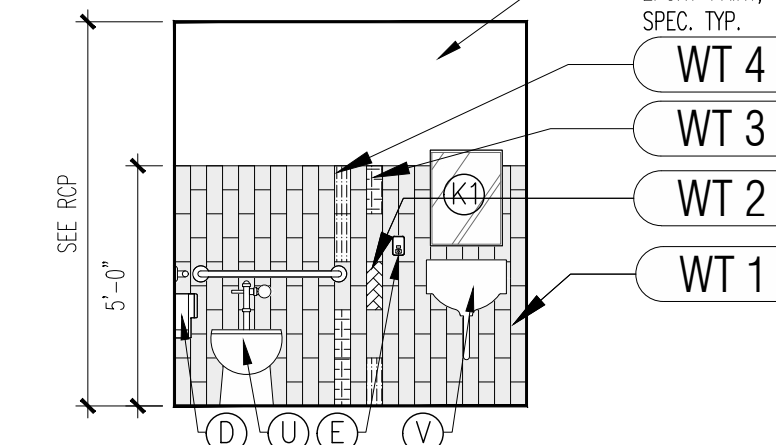


14 STAFF TOILET ELEVATION
A-713 Scale: 1/4"= 1'-0"

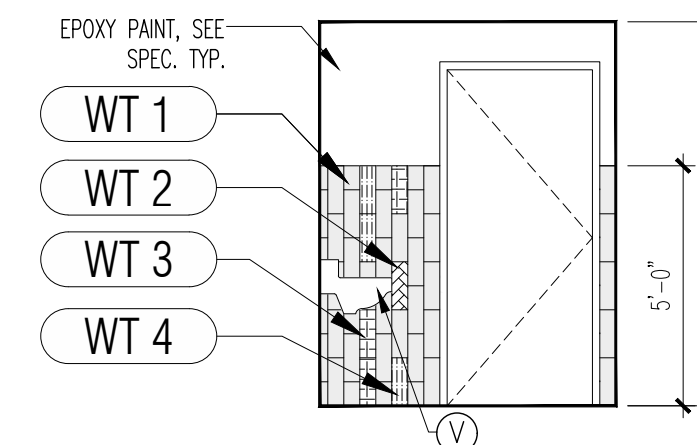


15 STAFF TOILET ELEVATION
A-713 Scale: 1/4"= 1'-0"

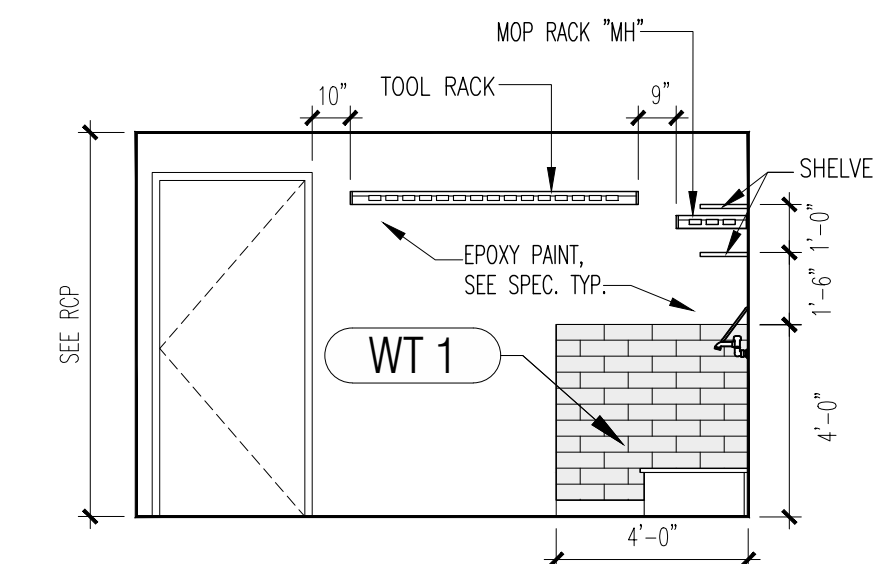


16 CUSTODIAL ELEVATION
A-713 Scale: 1/4"= 1'-0"

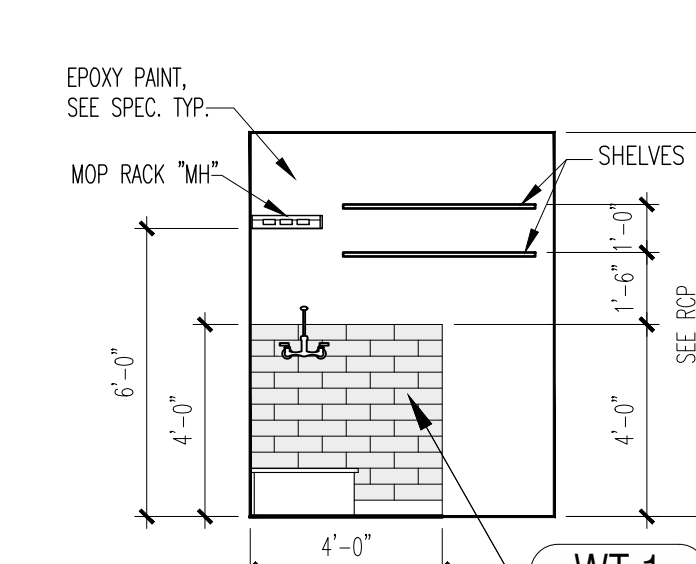


17 CUSTODIAL ELEVATION
A-713 Scale: 1/4"= 1'-0"

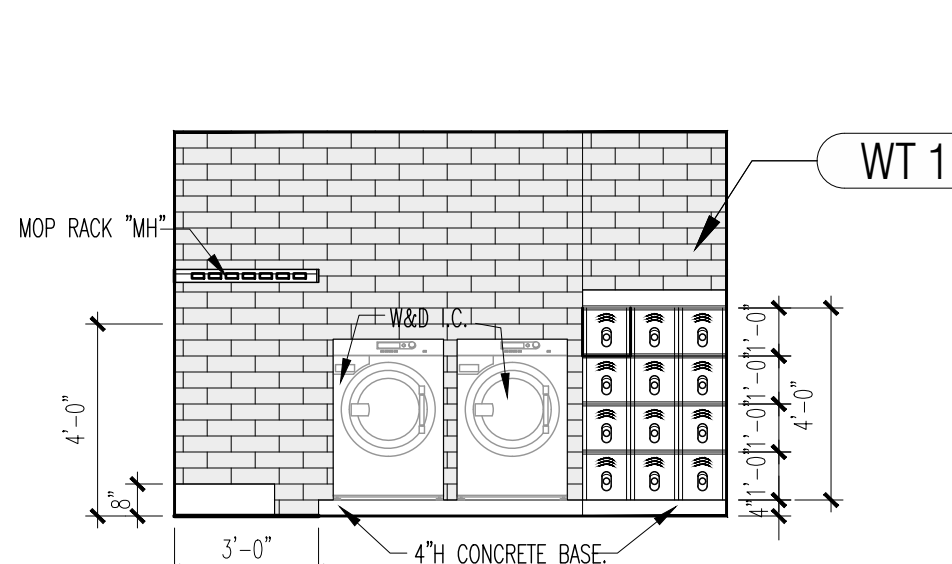


19 LAUNDRY ROOM ELEVATION
A-713 Scale: 1/4"= 1'-0"

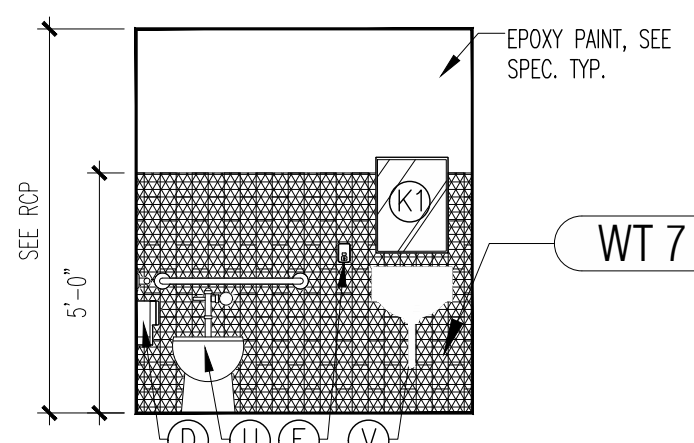


20 STAFF TOILET ELEVATION
A-713 Scale: 1/4"= 1'-0"

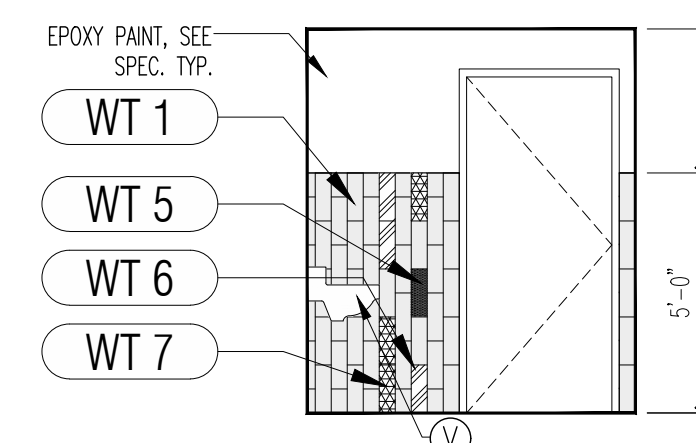






21 STAFF TOILET ELEVATION
A-713 Scale: 1/4"= 1'-0"

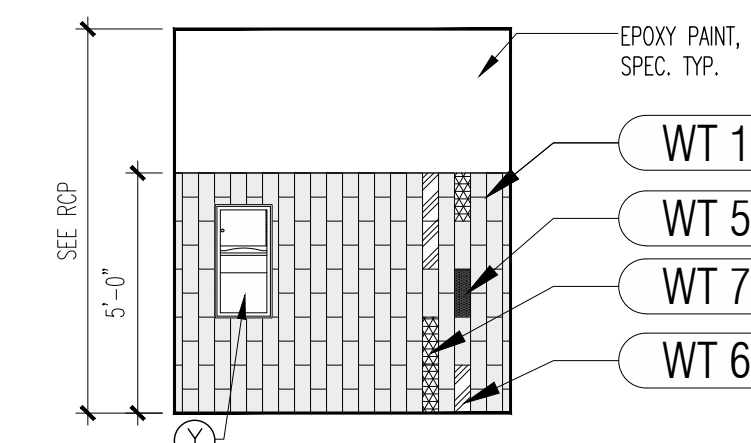

22 STAFF TOILET ELEVATION
A-713 Scale: 1/4"= 1'-0"

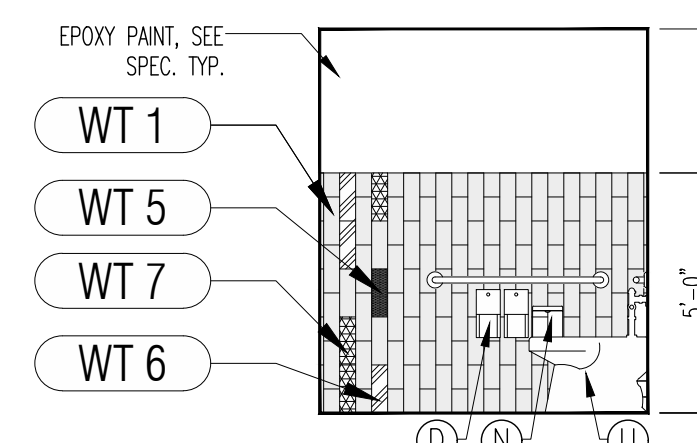

23 STAFF TOILET ELEVATION
A-713 Scale: 1/4"= 1'-0"

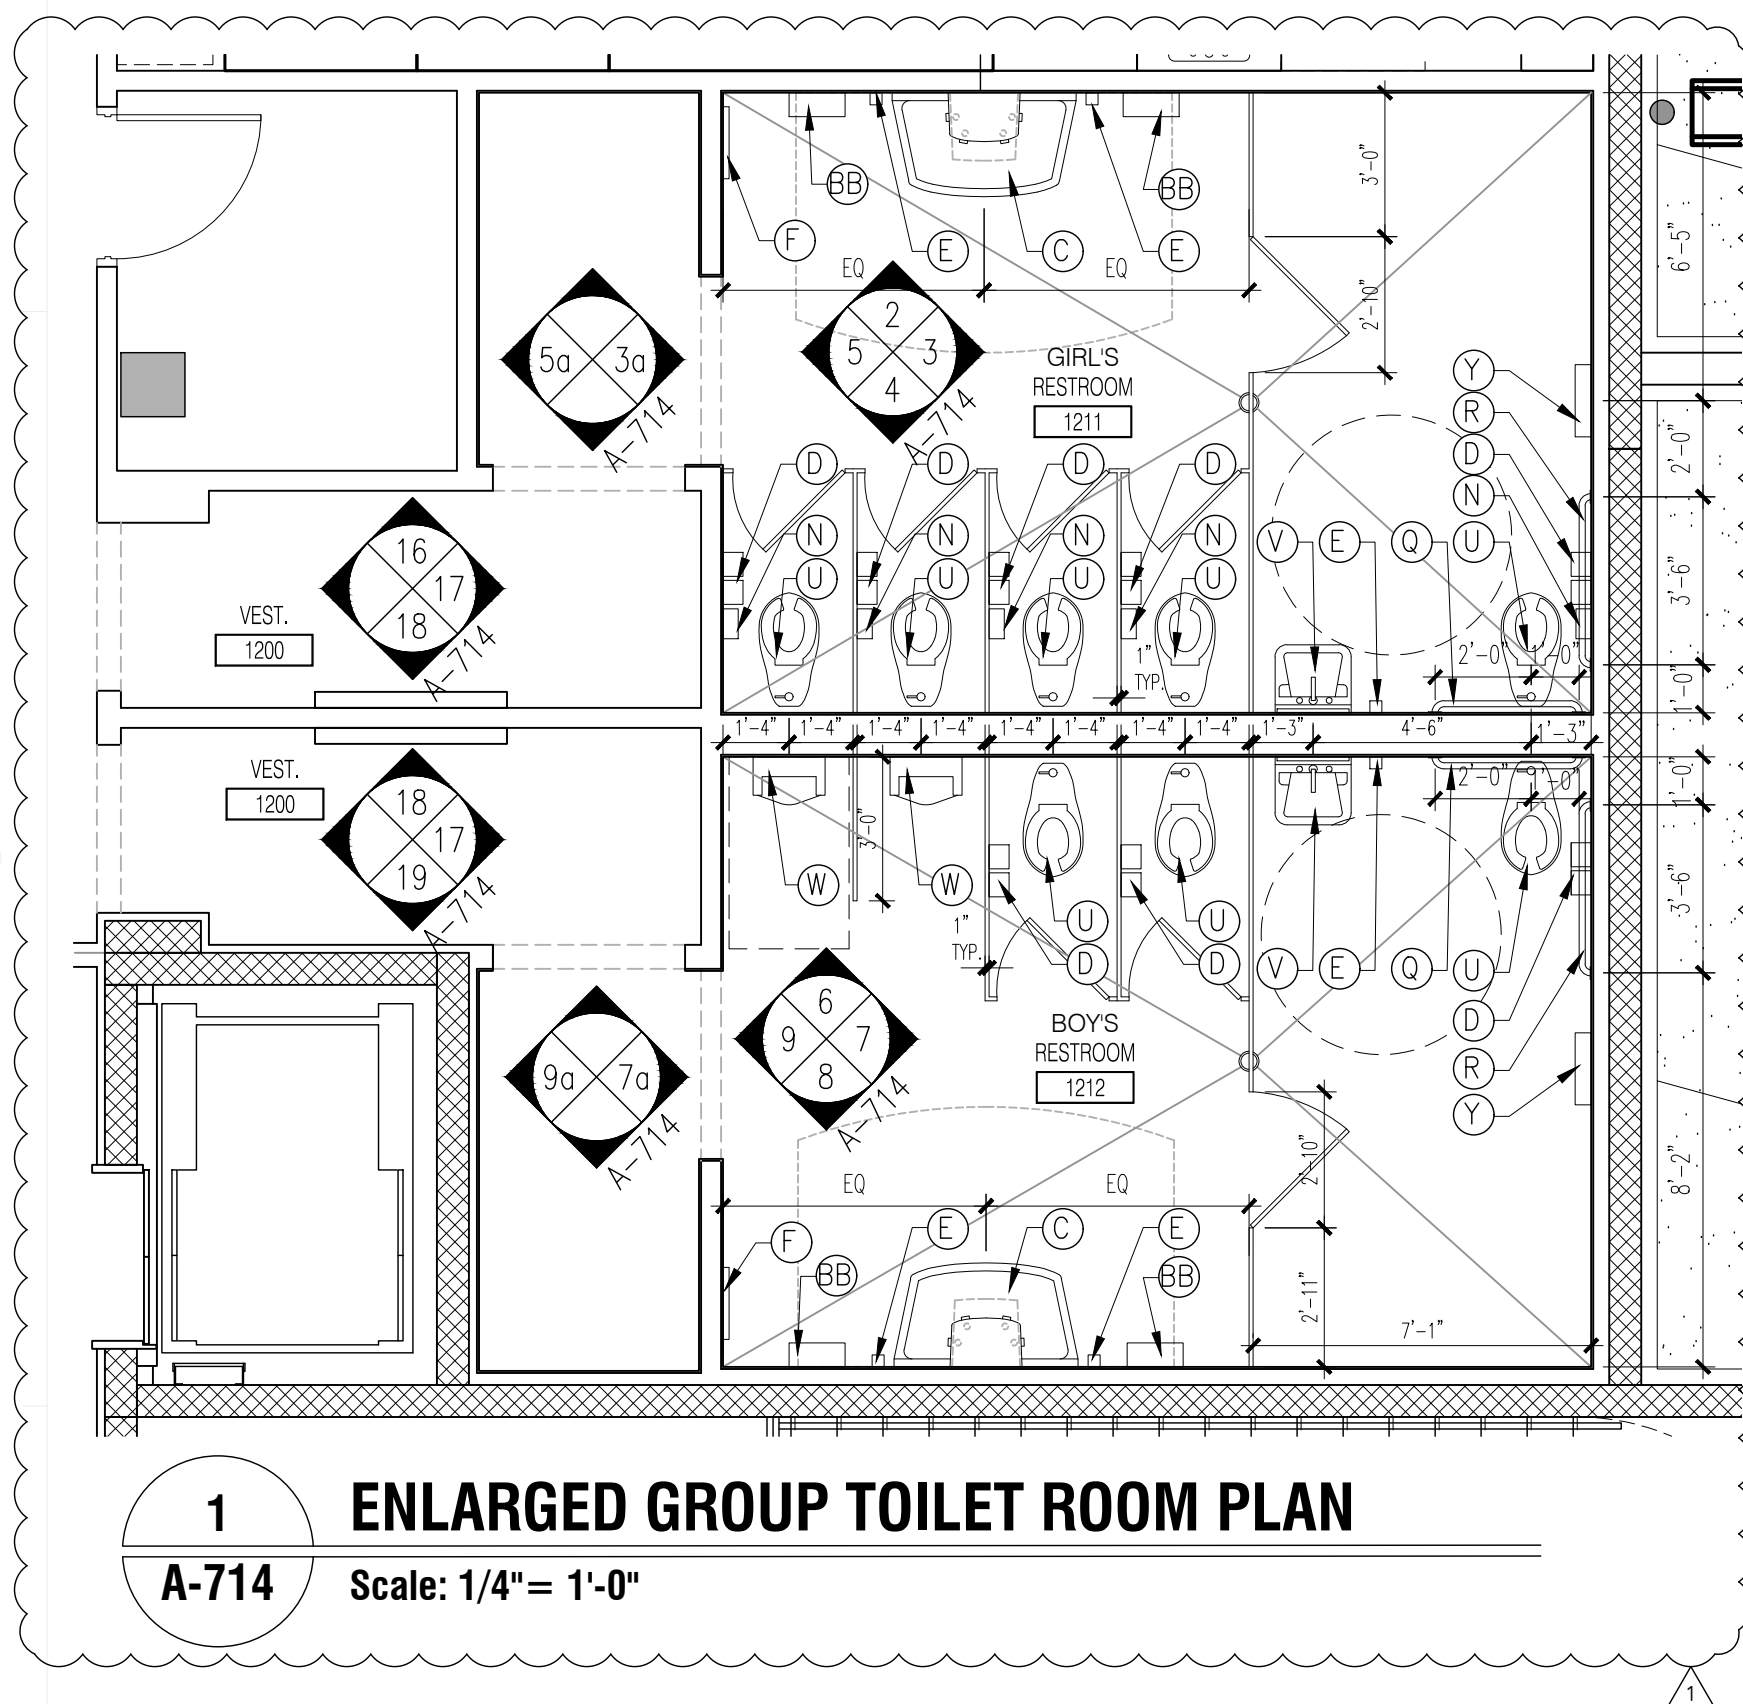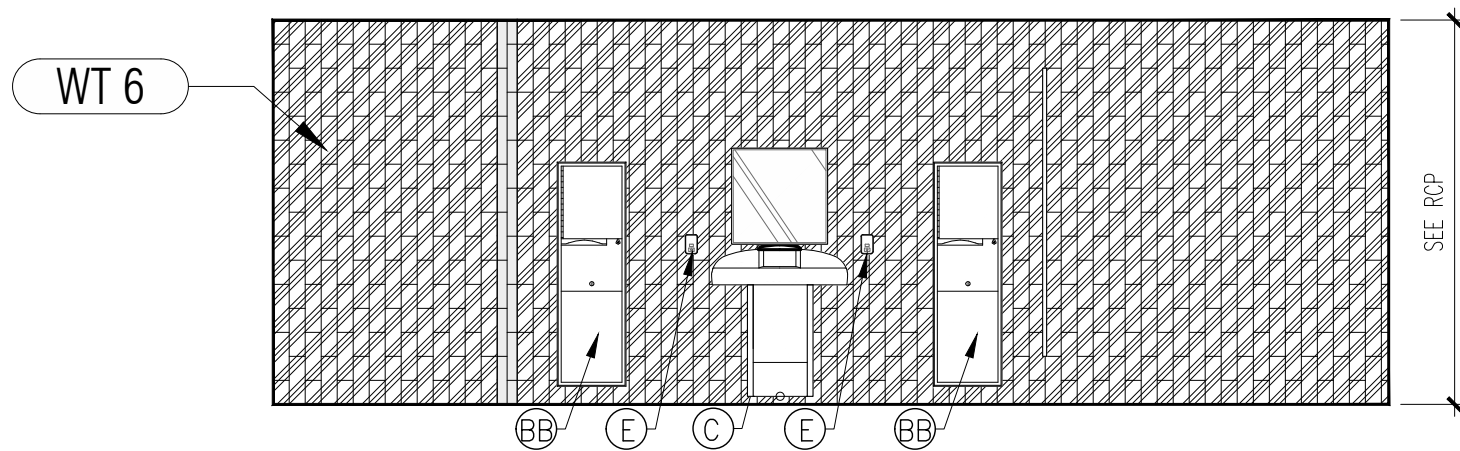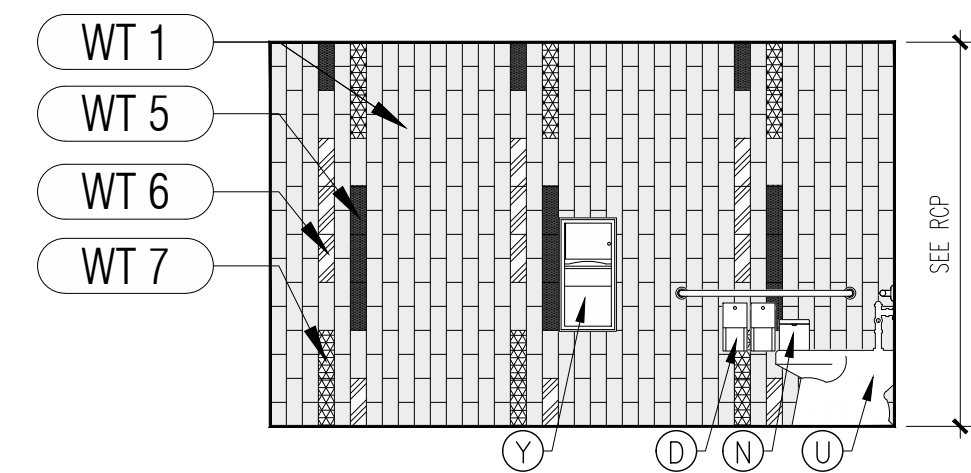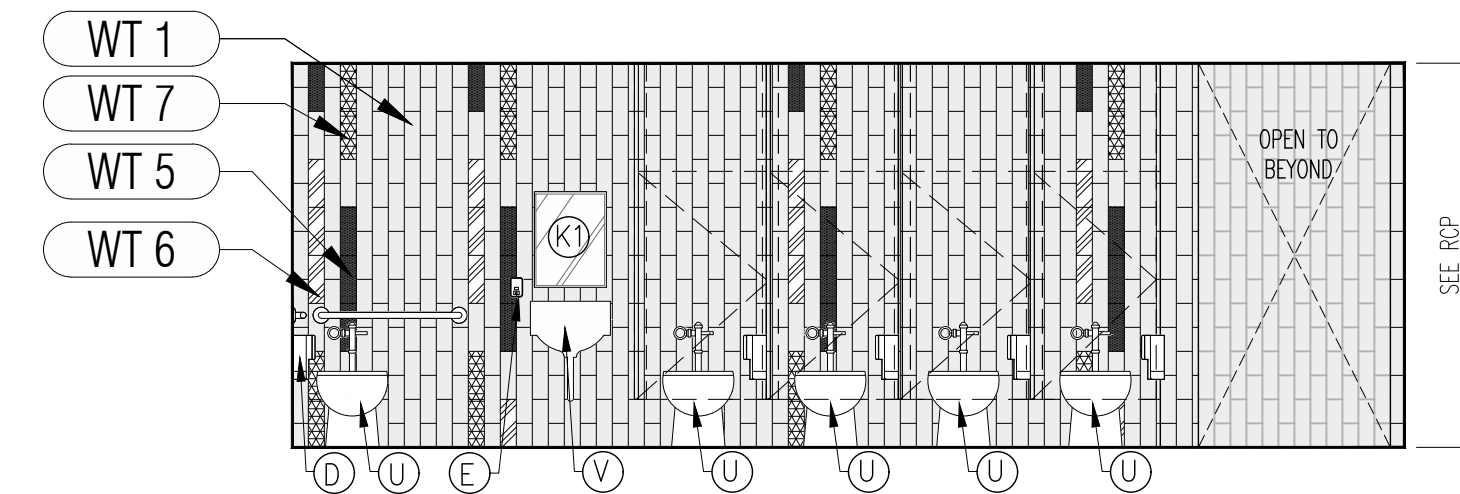
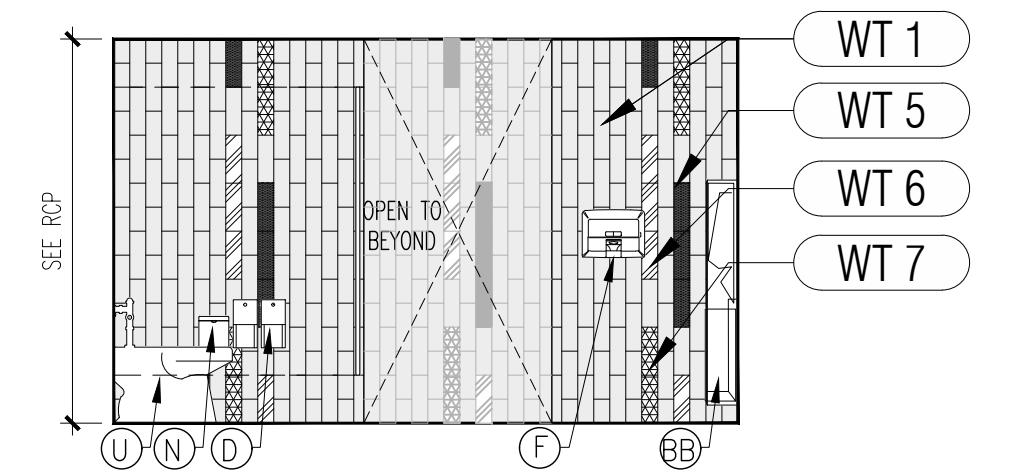


2 GIRL'S RESTROOM ELEVATION
A-714 Scale: 1/4"= 1'-0"



3 GIRL'S RESTROOM ELEVATION
A-714 Scale: 1/4"= 1'-0"

4 GIRL'S RESTROOM ELEVATION
A-714 Scale: 1/4"= 1'-0"

5 GIRL'S RESTROOM ELEVATION
A-714 Scale: 1/4"= 1'-0"

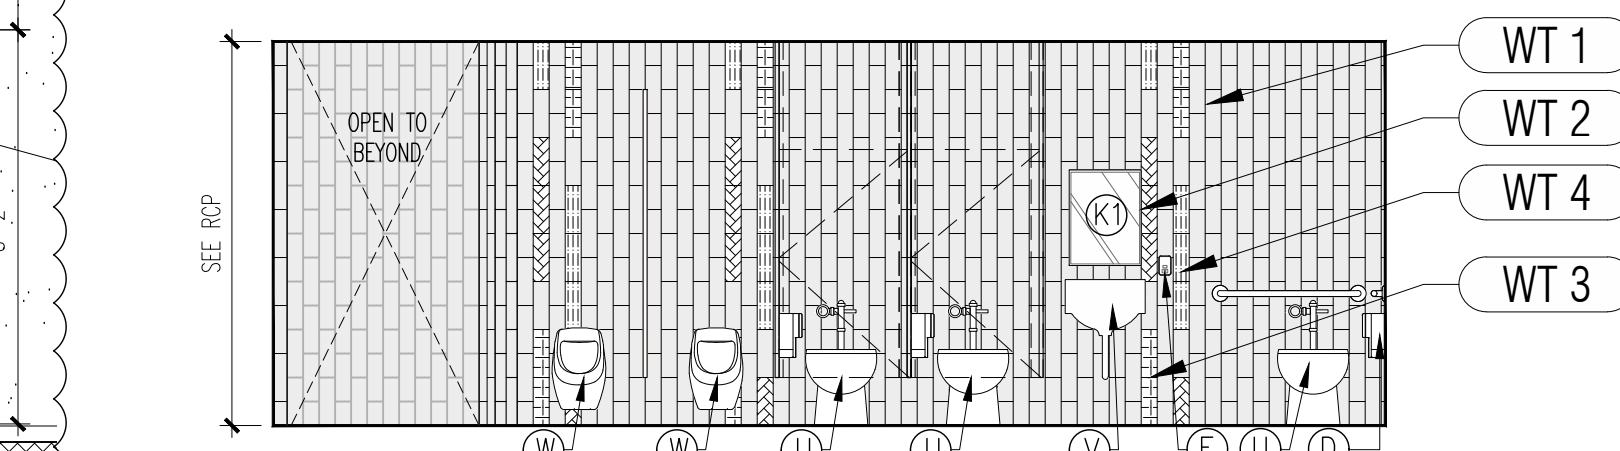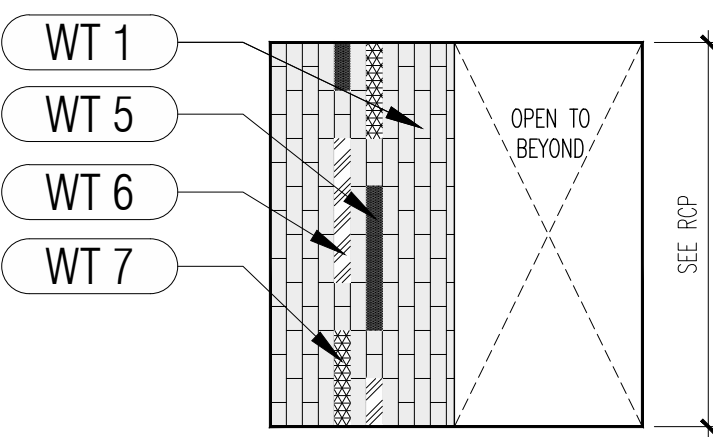

3a GIRL'S RESTROOM ELEVATION
A-714 Scale: 1/4"= 1'-0"

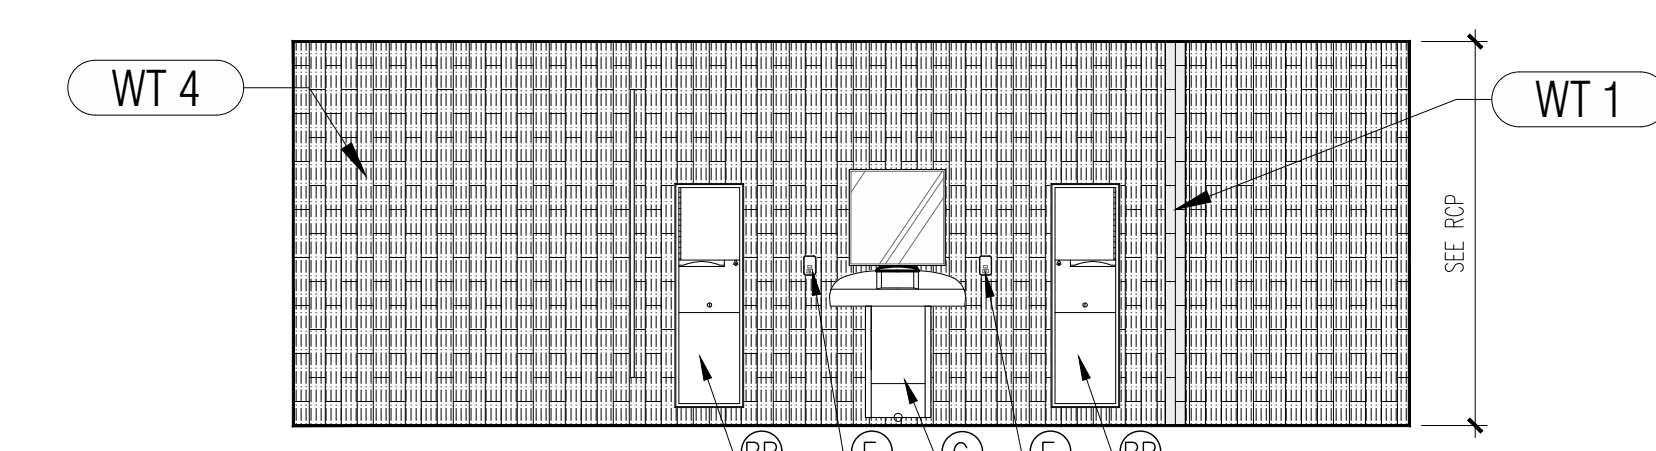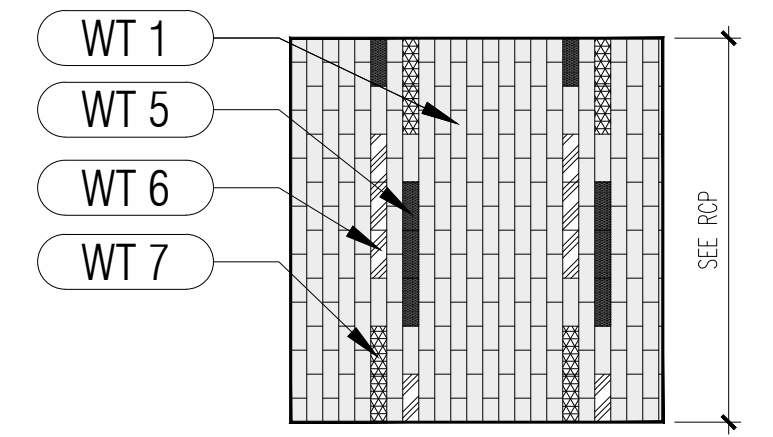


5a GIRL'S RESTROOM ELEVATION
A-714 Scale: 1/4"= 1'-0"

6 BOY'S RESTROOM ELEVATION
A-714 Scale: 1/4"= 1'-0"


7 BOY'S RESTROOM ELEVATION
A-714 Scale: 1/4"= 1'-0"

8 BOY'S RESTROOM ELEVATION
A-714 Scale: 1/4"= 1'-0"


9 BOY'S RESTROOM ELEVATION
A-714 Scale: 1/4"= 1'-0"

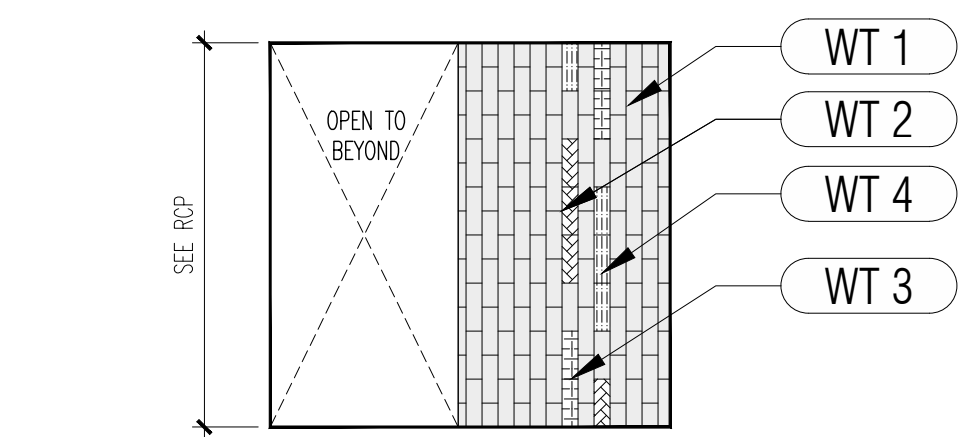


7a BOY'S RESTROOM ELEVATION
A-714 Scale: 1/4"= 1'-0"

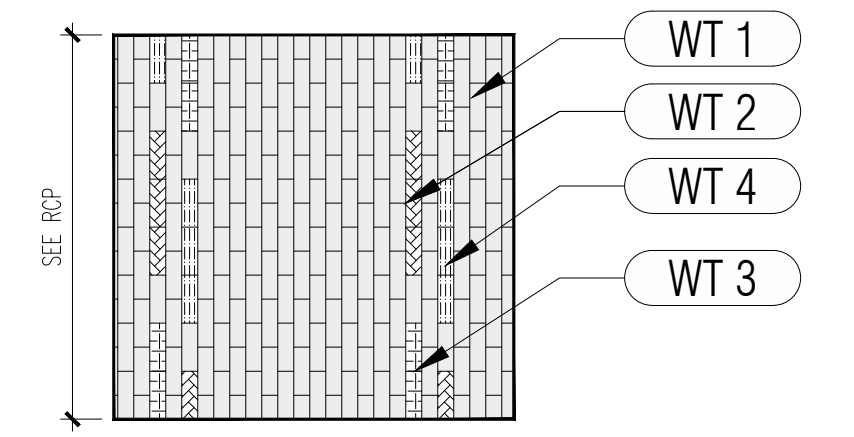


9a BOY'S RESTROOM ELEVATION
A-714 Scale: 1/4"= 1'-0"

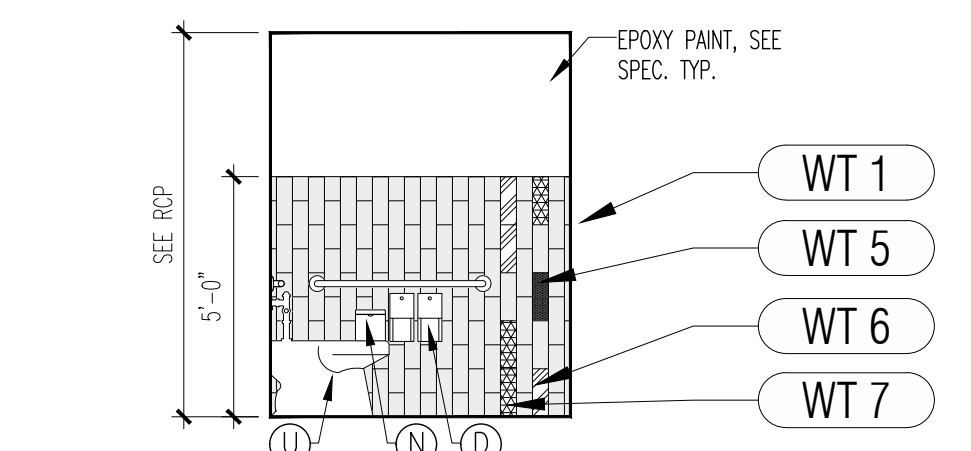


12 STAFF TOILET ELEVATION
A-714 Scale: 1/4"= 1'-0"

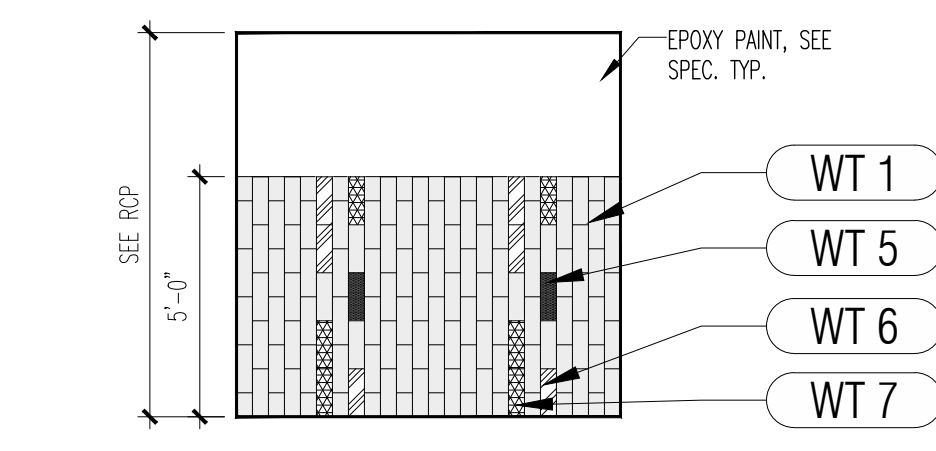


13 STAFF TOILET ELEVATION
A-714 Scale: 1/4"= 1'-0"

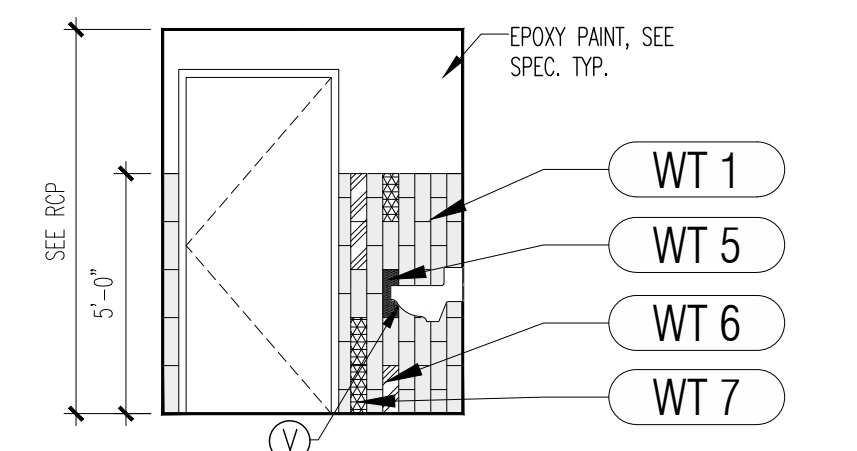


14 STAFF TOILET ELEVATION
A-714 Scale: 1/4"= 1'-0"

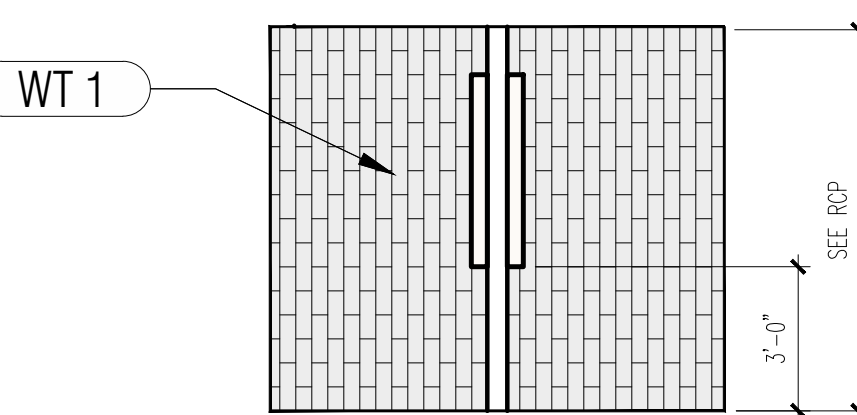


17 GIRL'S & BOY'S VESTIBULE ELEVATION
A-714 Scale: 1/4"= 1'-0"

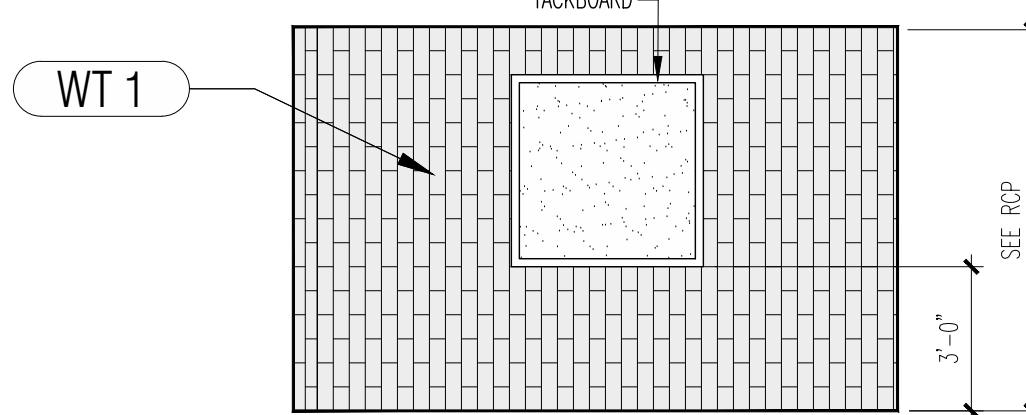


18 GIRL'S & BOY'S VESTIBULE ELEVATION
A-714 Scale: 1/4"= 1'-0"

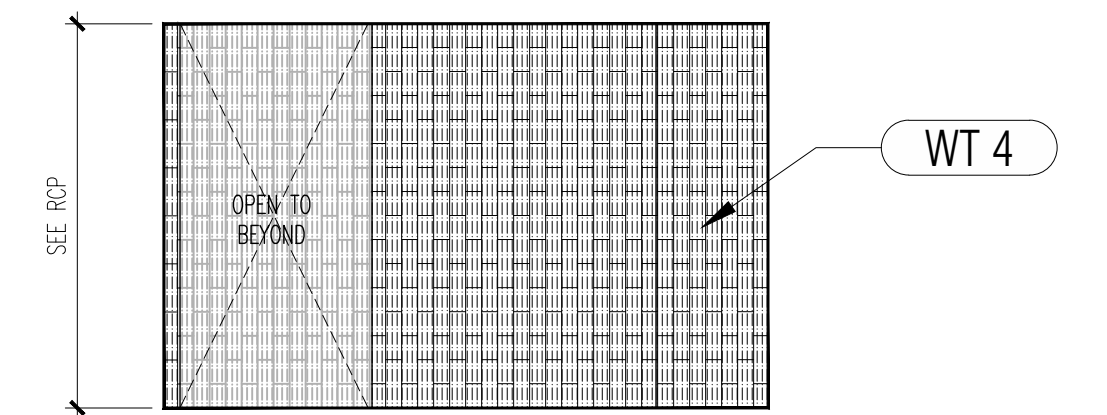


19 BOY'S VESTIBULE ELEVATION
A-714 Scale: 1/4"= 1'-0"

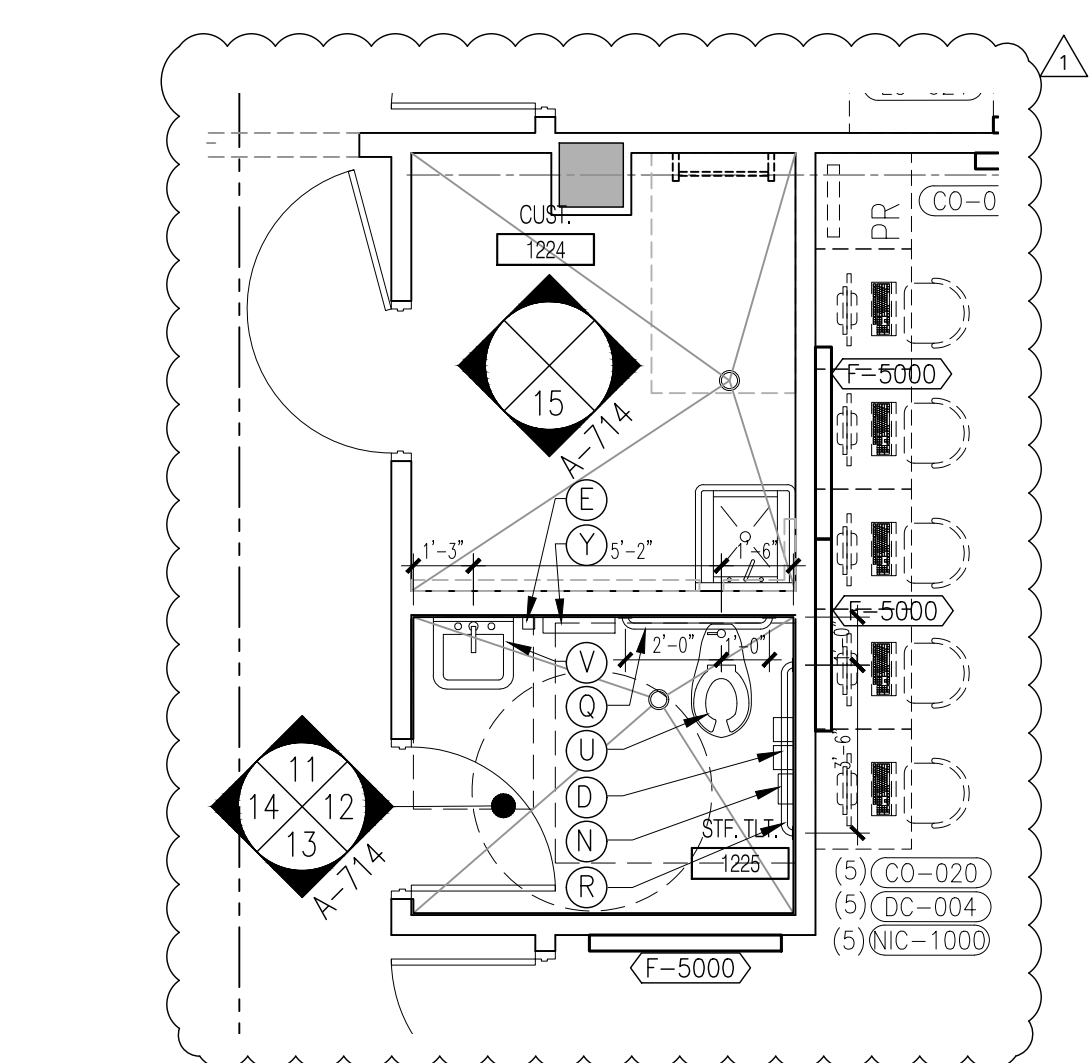


10 ENLARGED TOILET ROOM PLAN-STAFF/CUSTODIAL
A-714 Scale: 1/4"= 1'-0"

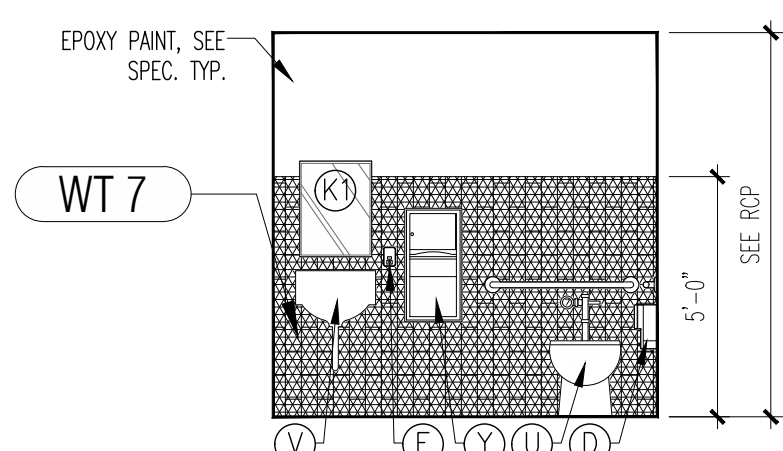

11 STAFF TOILET ELEVATION
A-714 Scale: 1/4"= 1'-0"

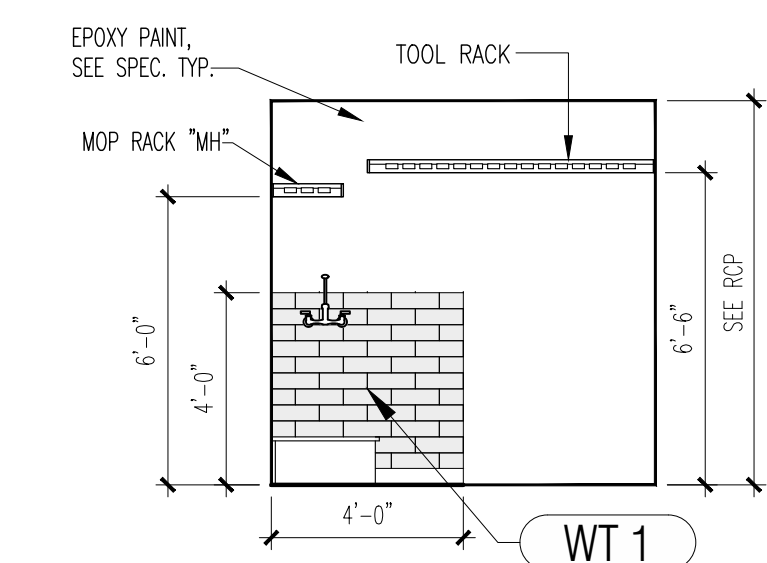


15 CUSTODIAL ELEVATION
A-714 Scale: 1/4"= 1'-0"

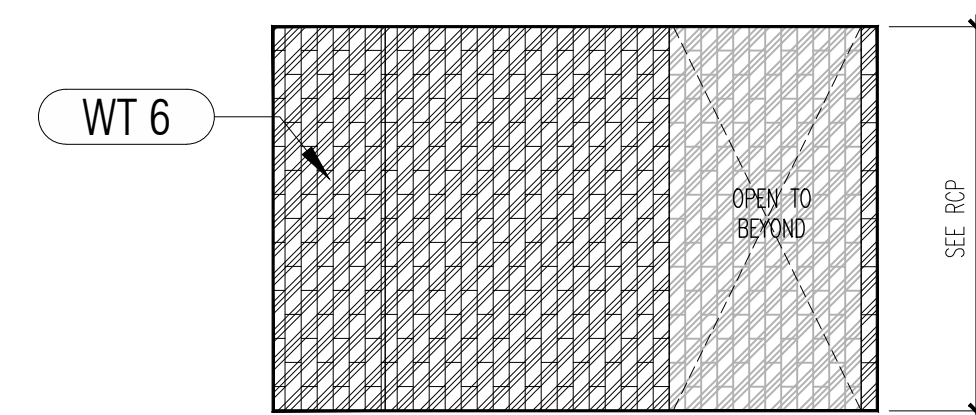

16 GIRL'S VESTIBULE ELEVATION
A-714 Scale: 1/4"= 1'-0"

NEW ELEMENTARY SCHOOL (K-5)
VENETIAN PARC WEST
SOUTHWEST 157th AVENUE and 174th STREET
MIAMI, FL. 33187
MDCPS PROJECT No. 01892600

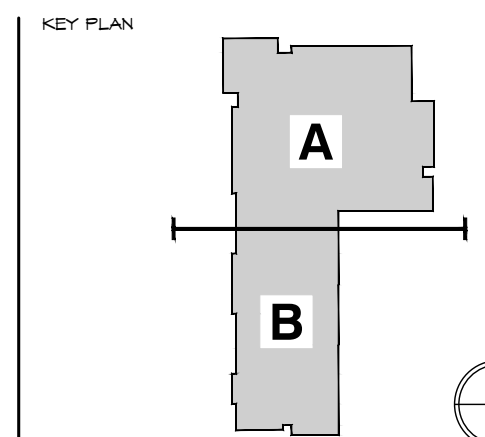


CONSULTANT INFO:

RODRIGUEZ ARCHITECTS
INCORPORATED
2121 PONCE DE LEON BLVD. STE. 1010
CORAL GABLES, FL. 33134
TEL: (305) 448-3373
FAX: (305) 448-3374
A A C — 0 0 1 9 3 3


REVISIONS:
02/14/2020 BUILDING DEPARTMENT COMMENTS

RAI


DRAWING TITLE:
ENLARGED TOILET PLANS & ELEVATIONS
SCALE AS NOTED
ISSUE DATE: 12/16/19
PROJECT NO. 1906
SHEET: A-714

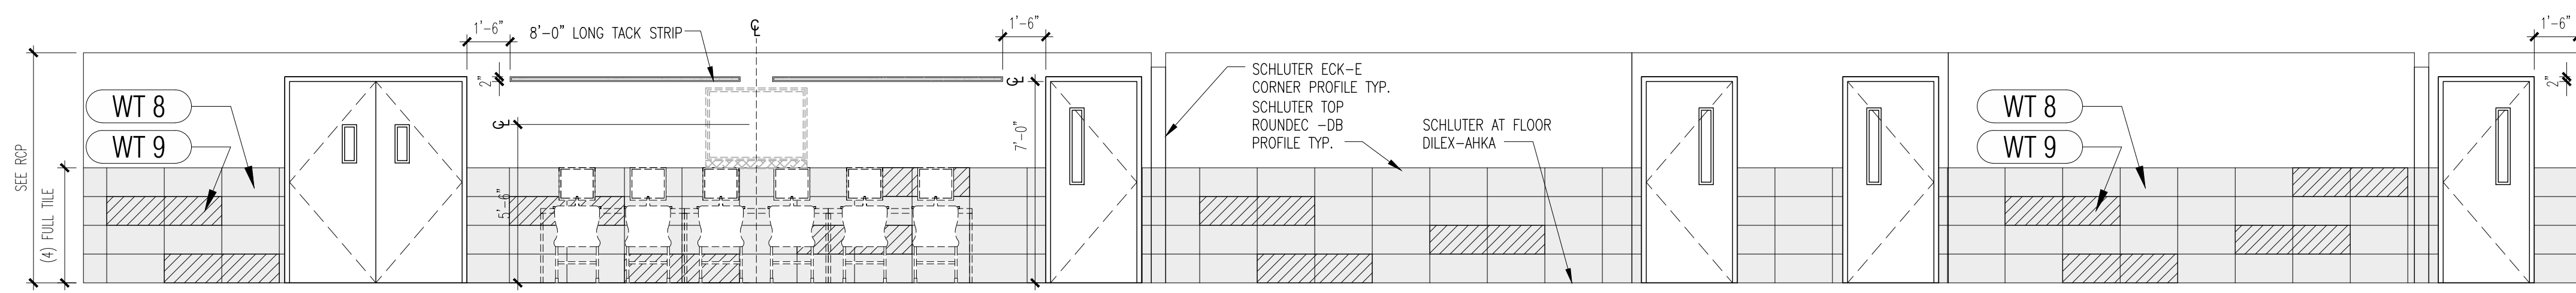


2 ENLARGED TYPICAL EXTENDED LEARNING
A-715 Scale: 1/4" = 1'-0"

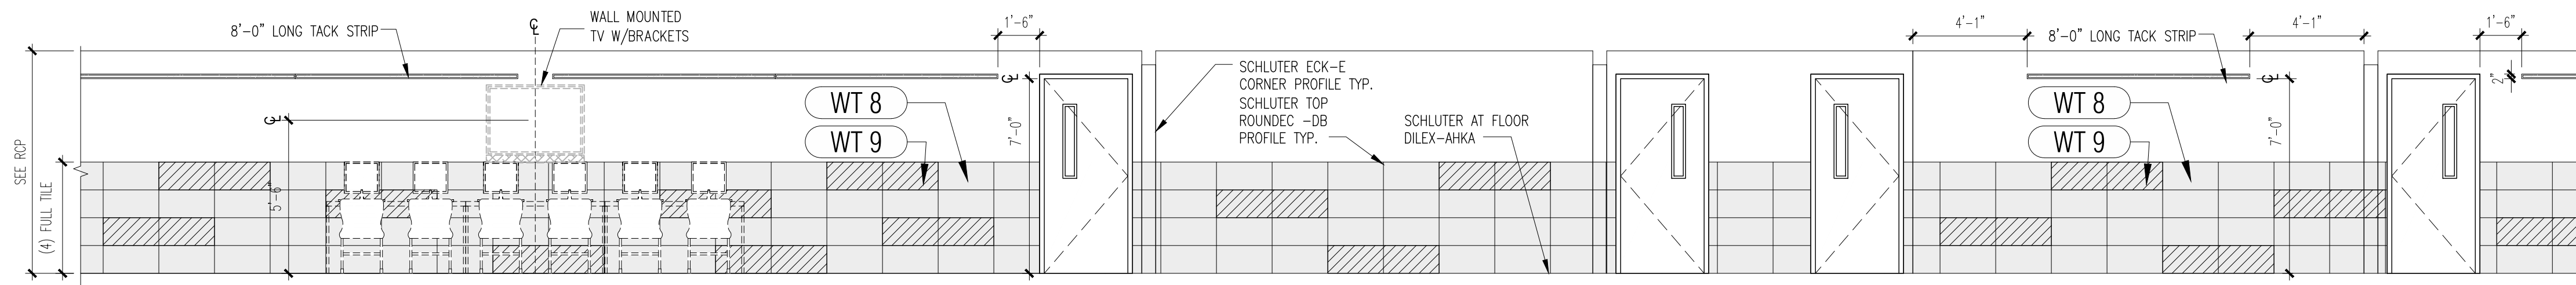


3 ENLARGED TYPICAL EXTENDED LEARNING CONT'D
A-715 Scale: 1/4" = 1'-0"

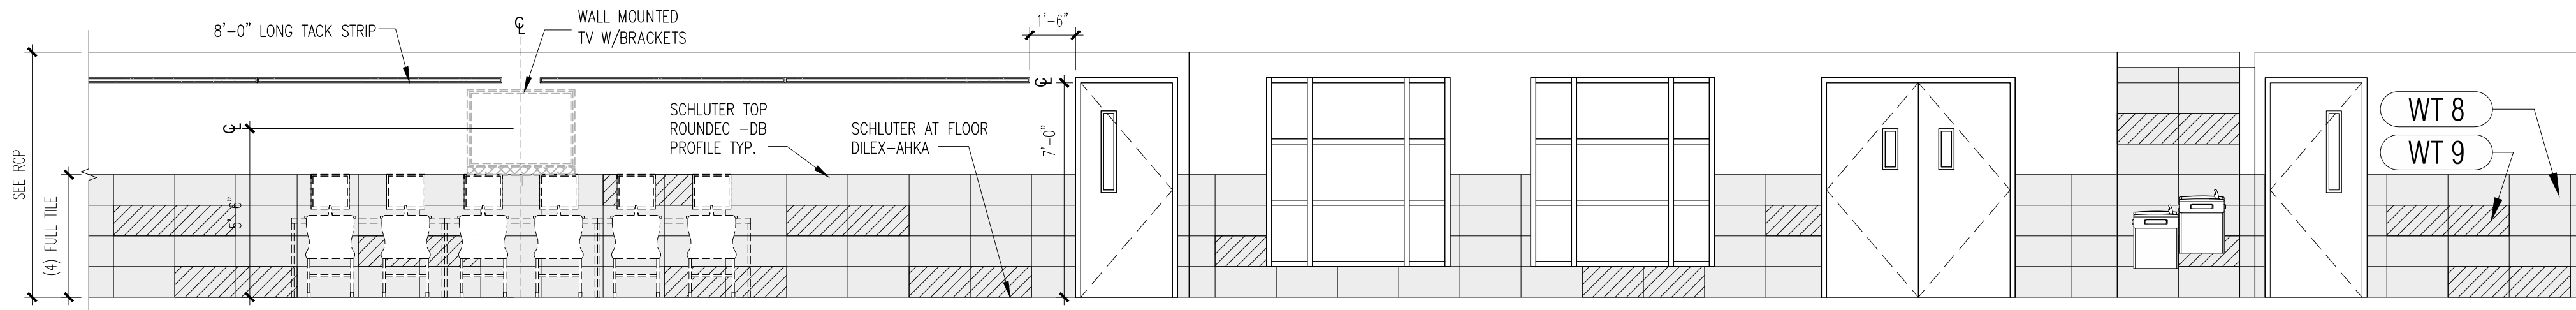


4 ENLARGED TYPICAL EXTENDED LEARNING CONT'D
A-715 Scale: 1/4" = 1'-0"

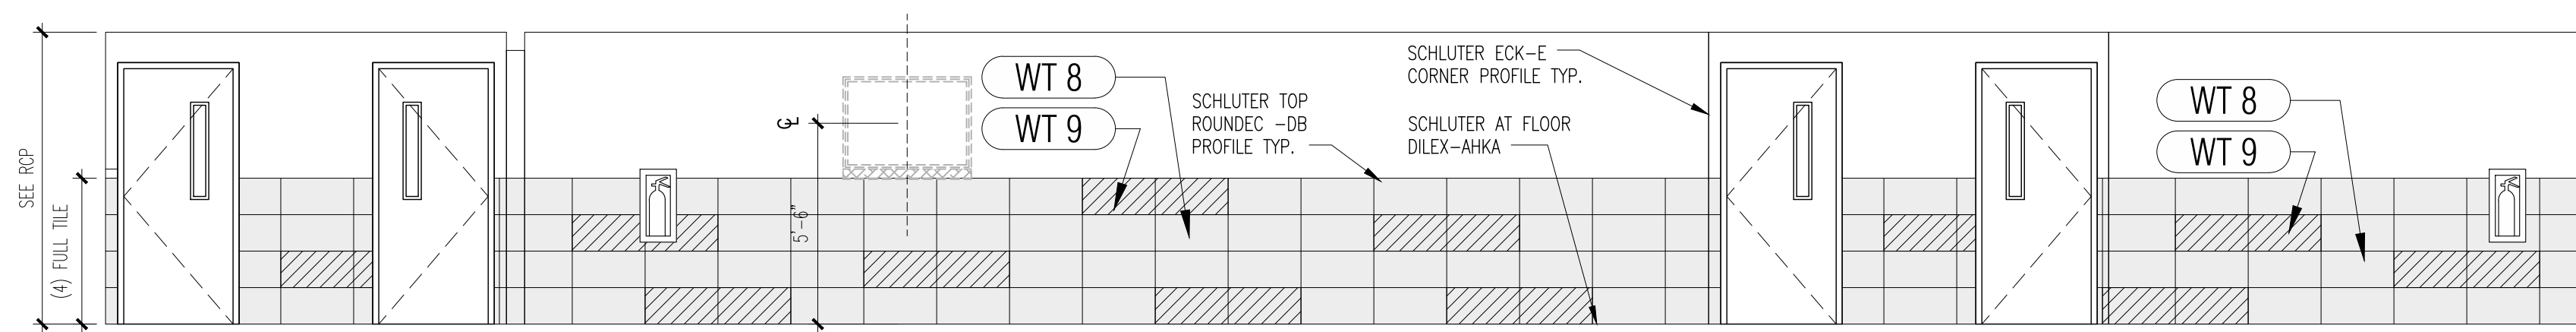


5 ENLARGED TYPICAL EXTENDED LEARNING CONT'D
A-715 Scale: 1/4" = 1'-0"

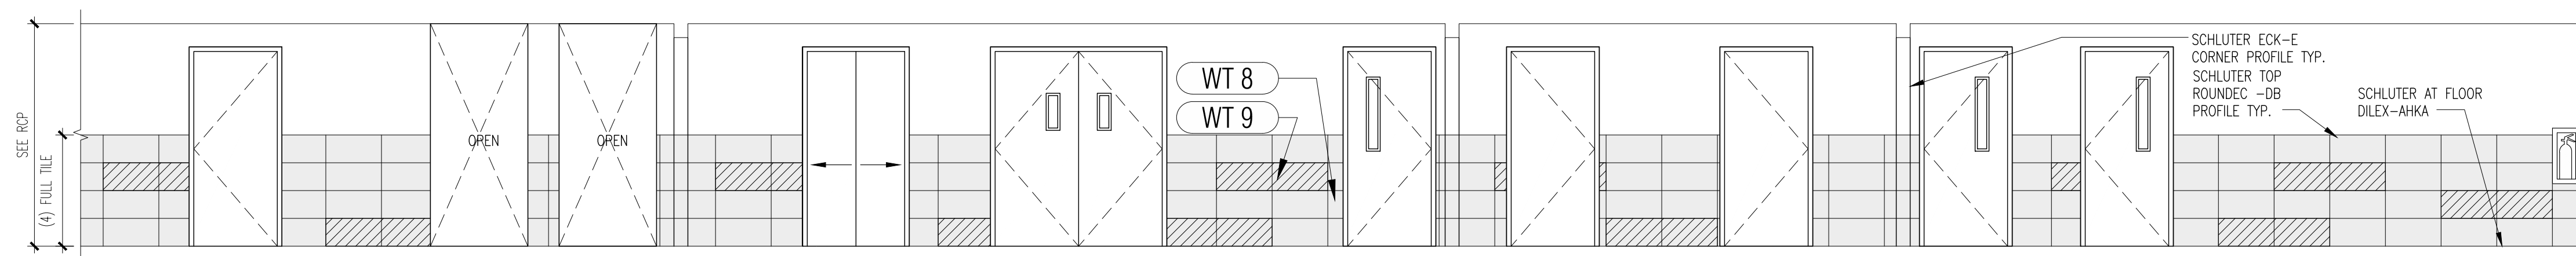


6 ENLARGED TYPICAL EXTENDED LEARNING CONT'D
A-715 Scale: 1/4" = 1'-0"

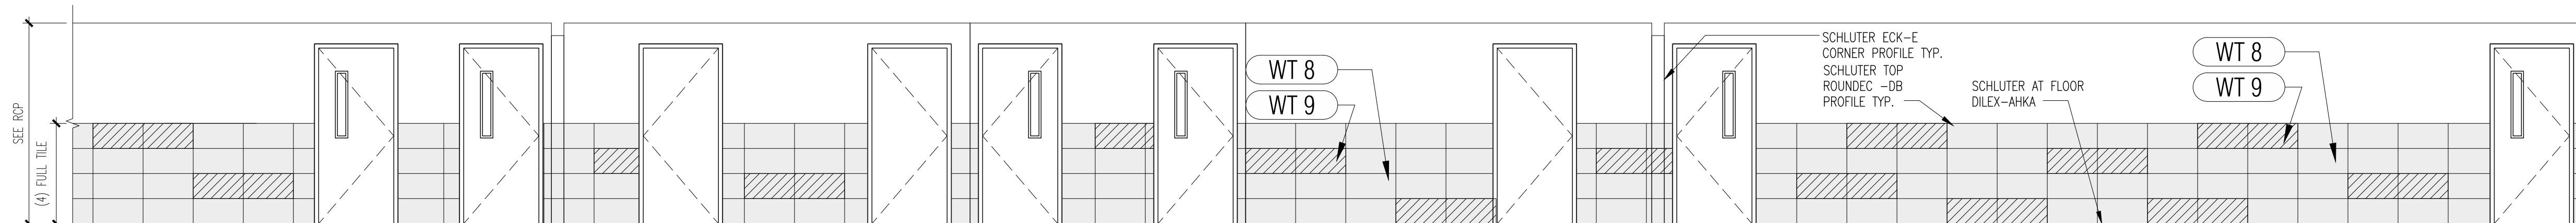




7 ENLARGED TYPICAL EXTENDED LEARNING CONT'D
A-715 Scale: 1/4" = 1'-0"




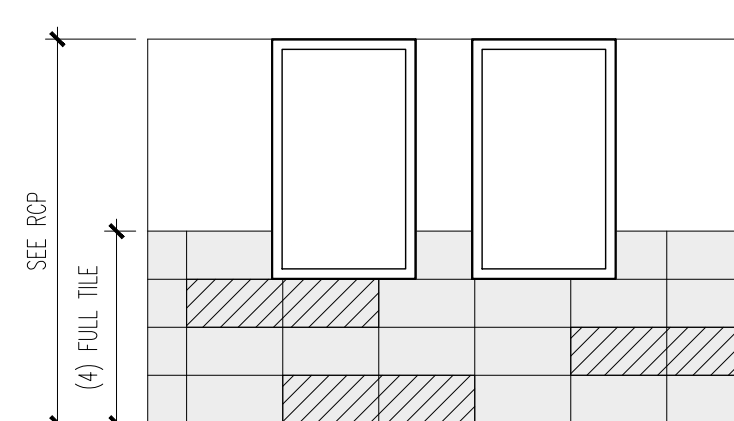



8 EXLARGED TYPICAL EXTENDED LEARNING THRESHOLD
A-715 Scale: 1/4" = 1'-0"

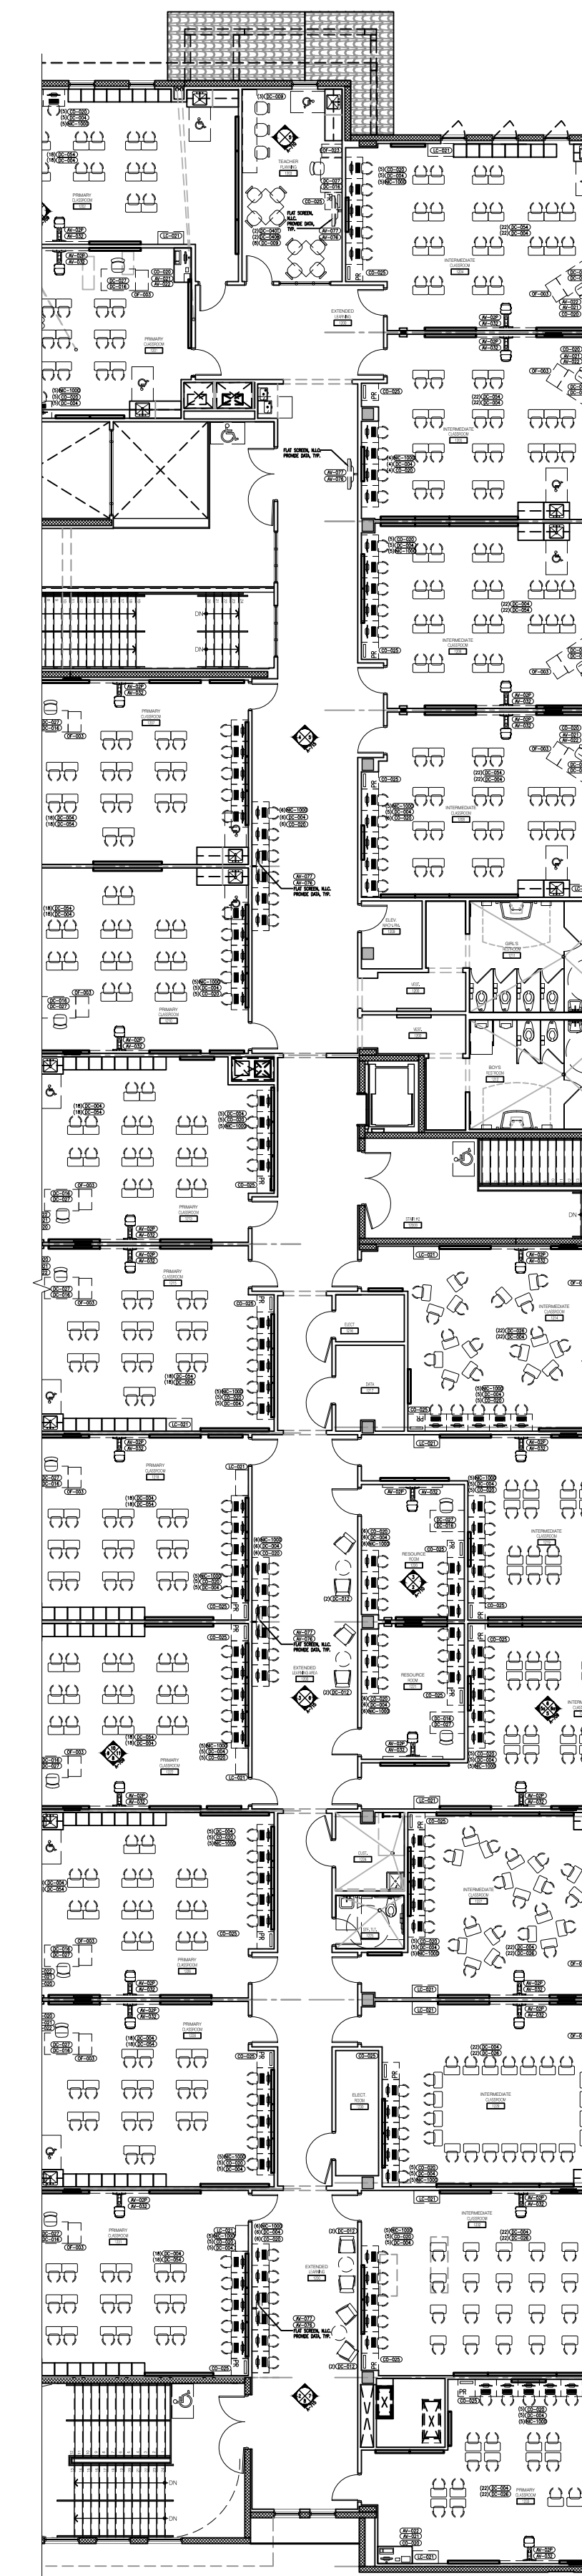

1 ENLARGED TYPICAL EXTENDED LEARNING PLAN
A-715 Scale: 1/16" = 1'-0"

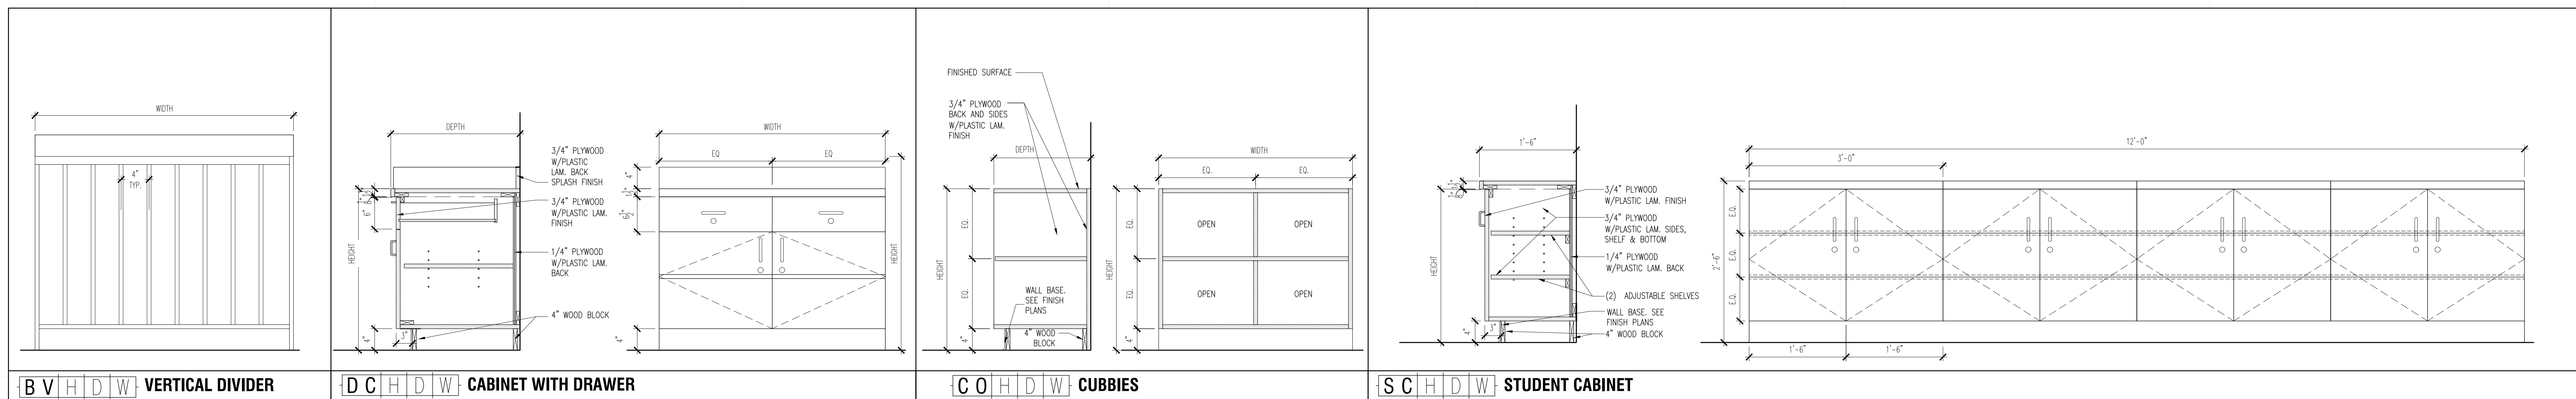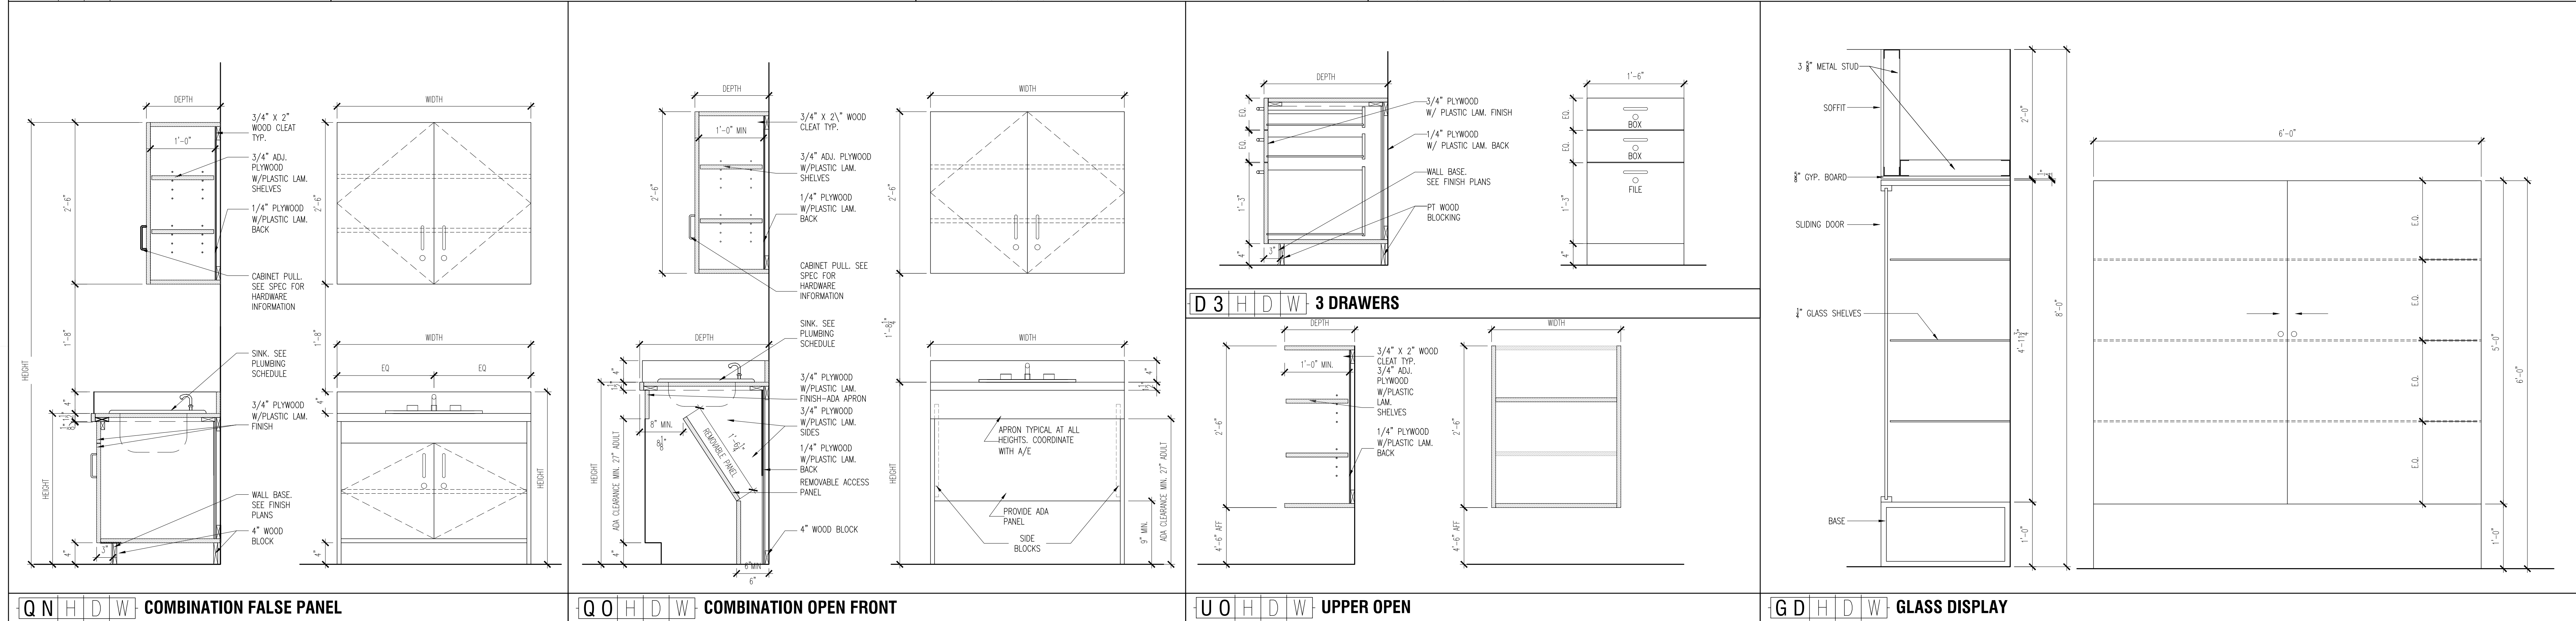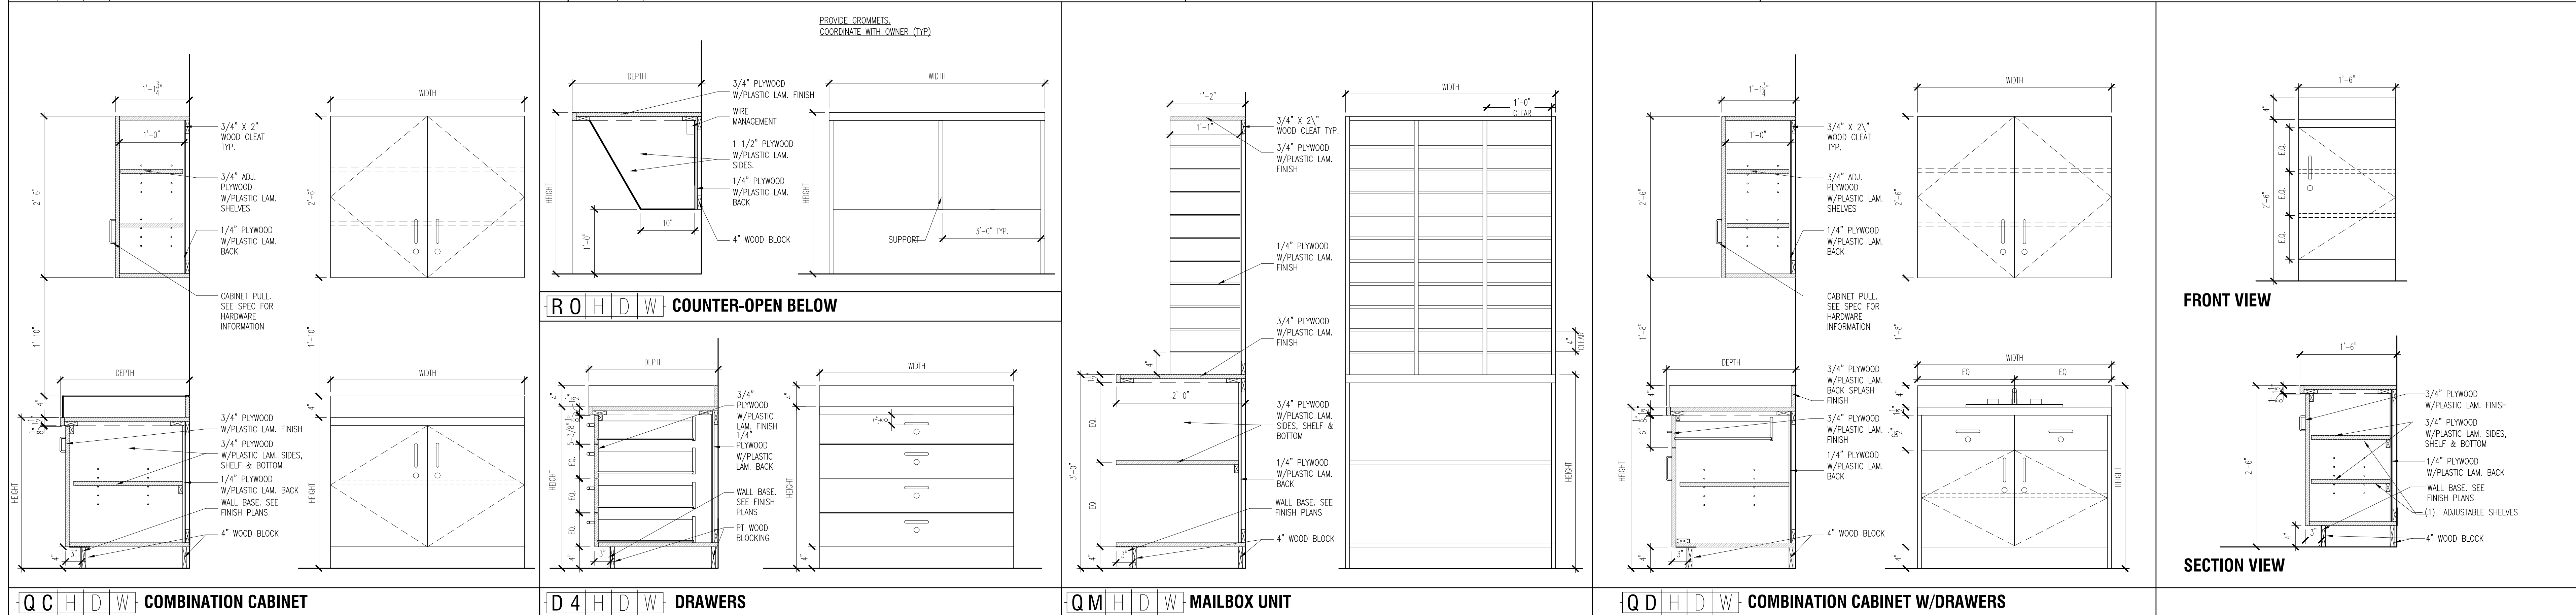

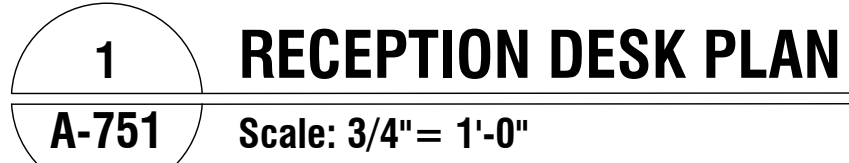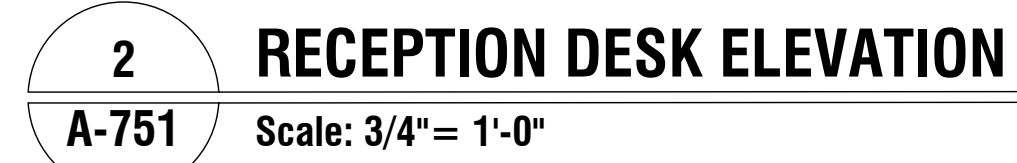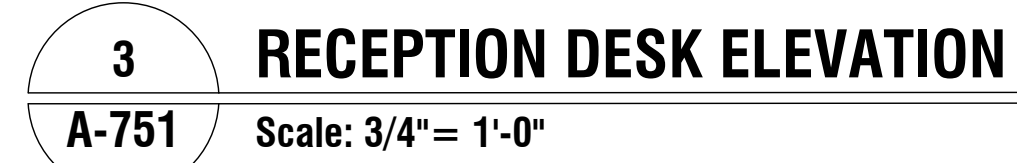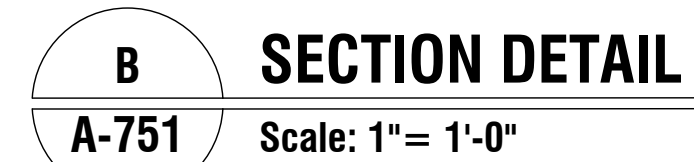


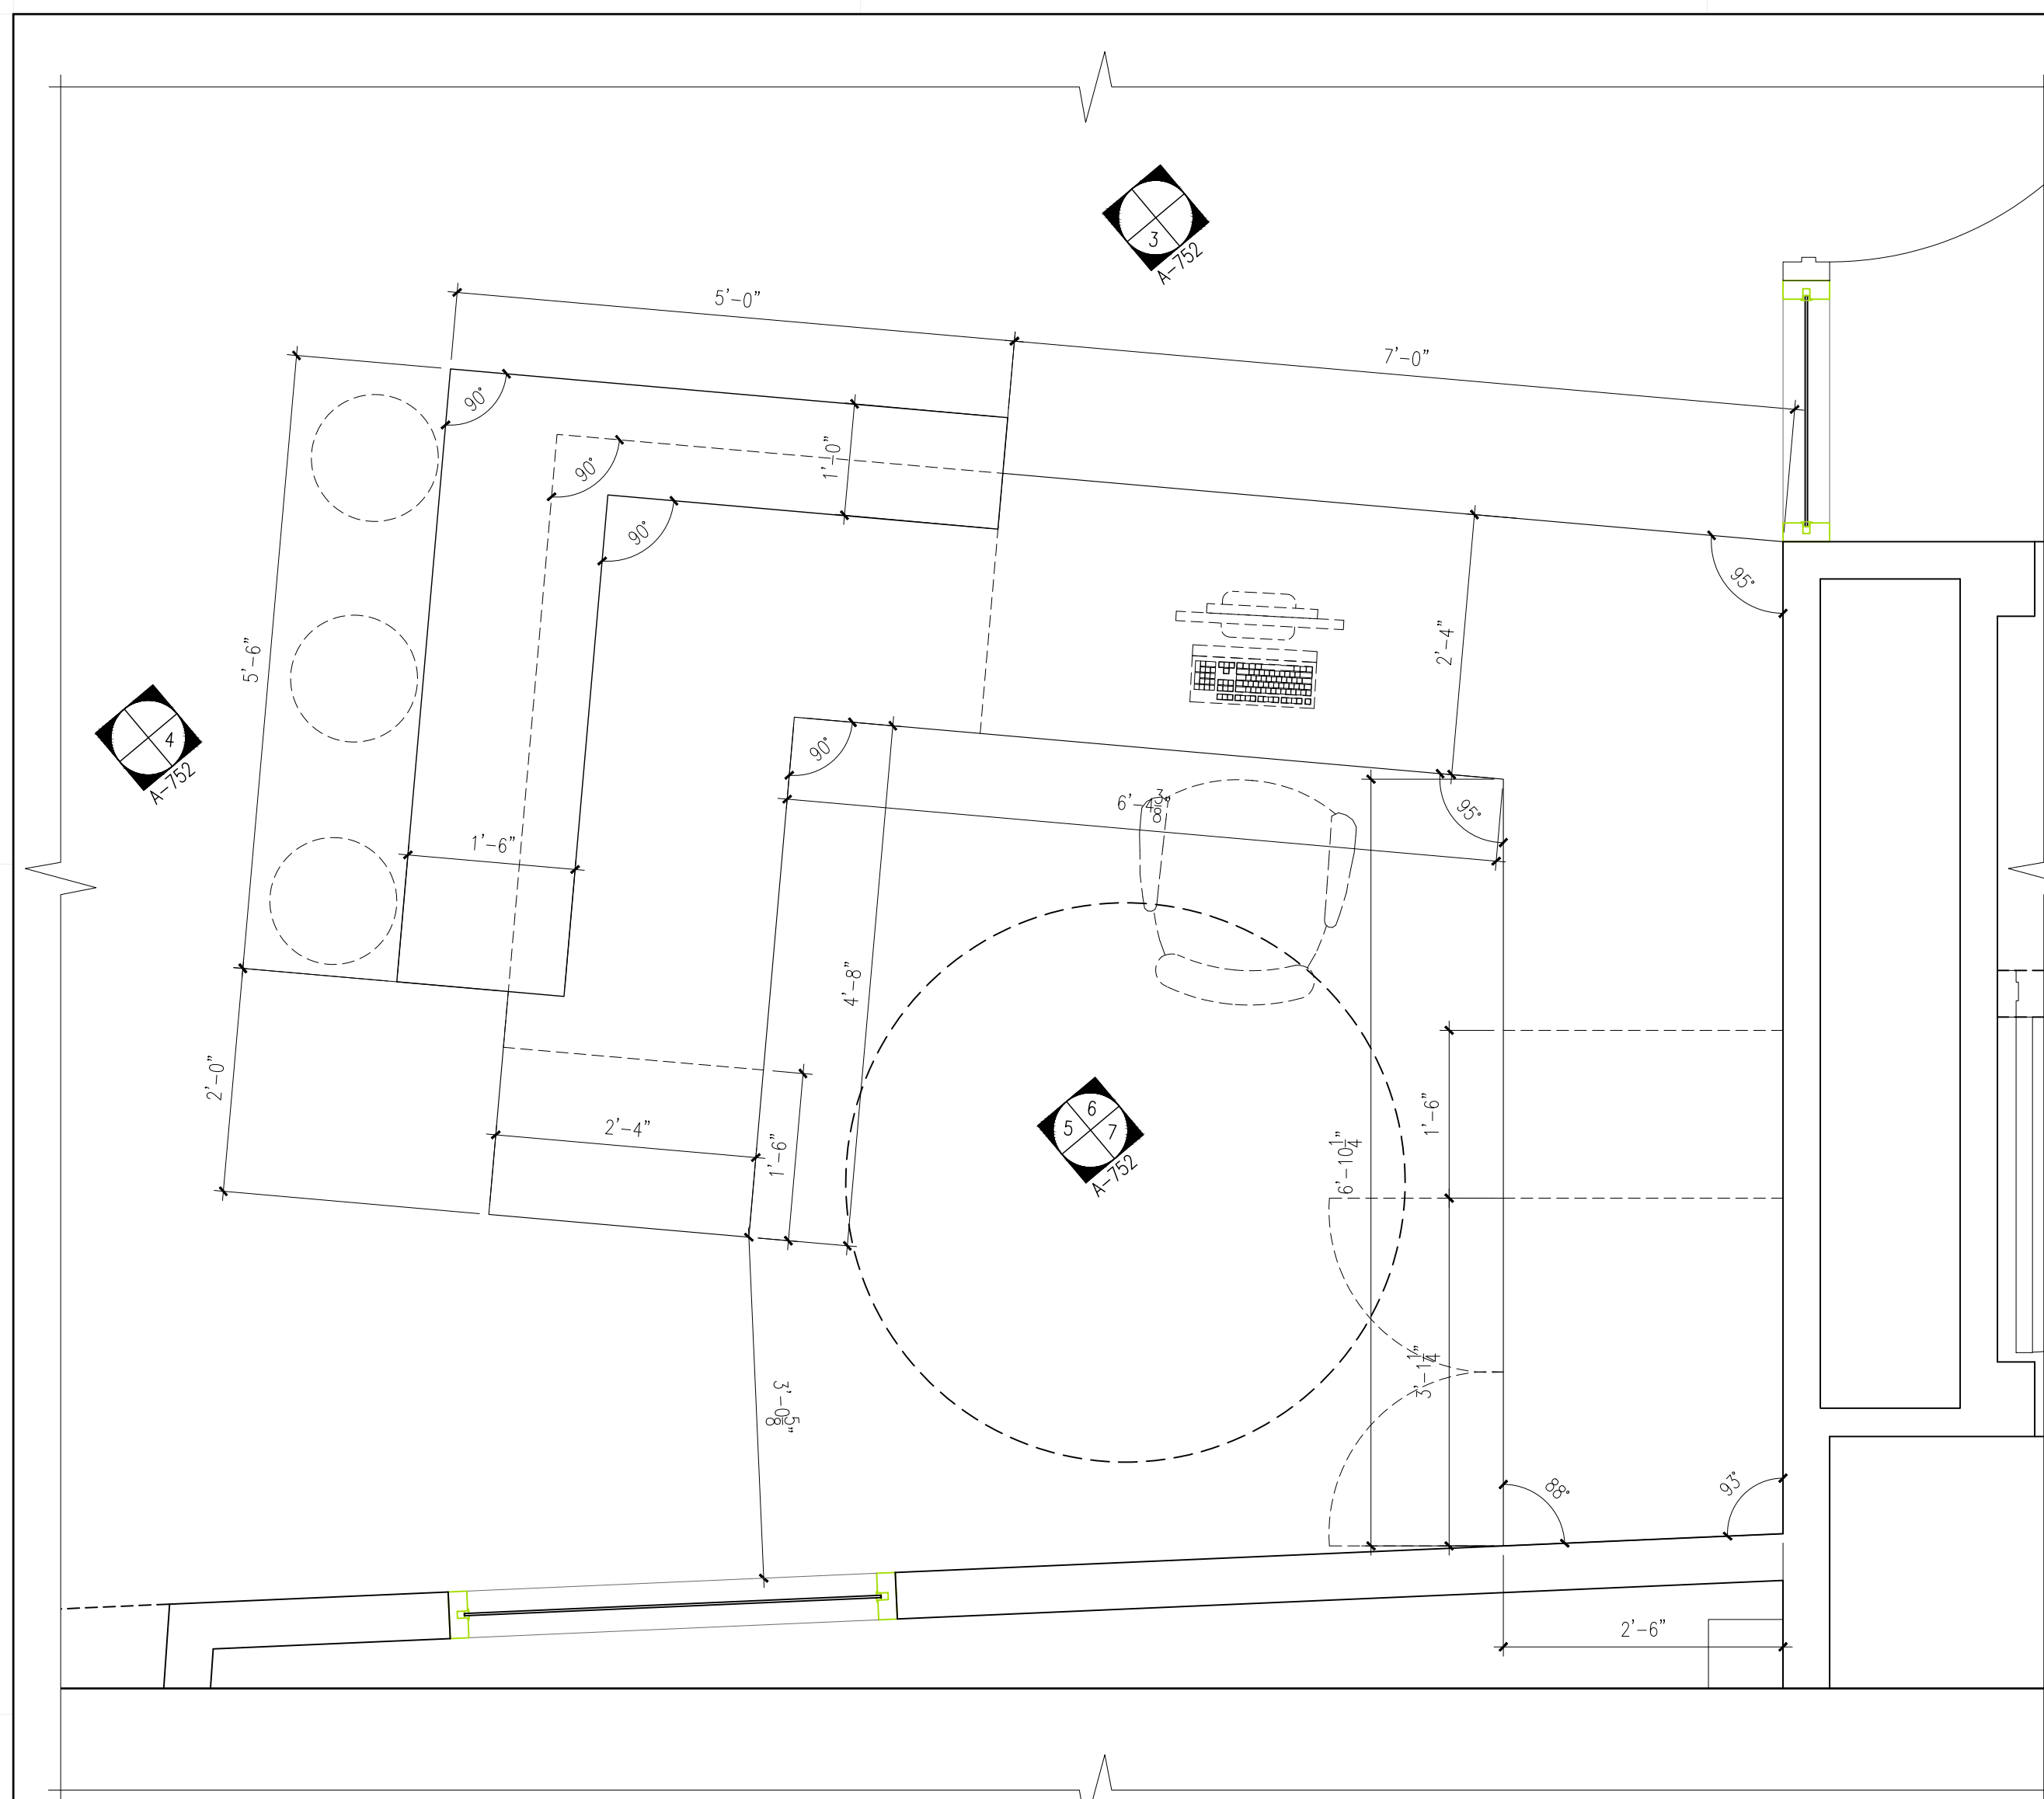


1 MEDIA DESK PLAN
A-752 Scale: 3/4" = 1'-0"




2 FRAMING PLAN
A-752 Scale: 3/4" = 1'-0"

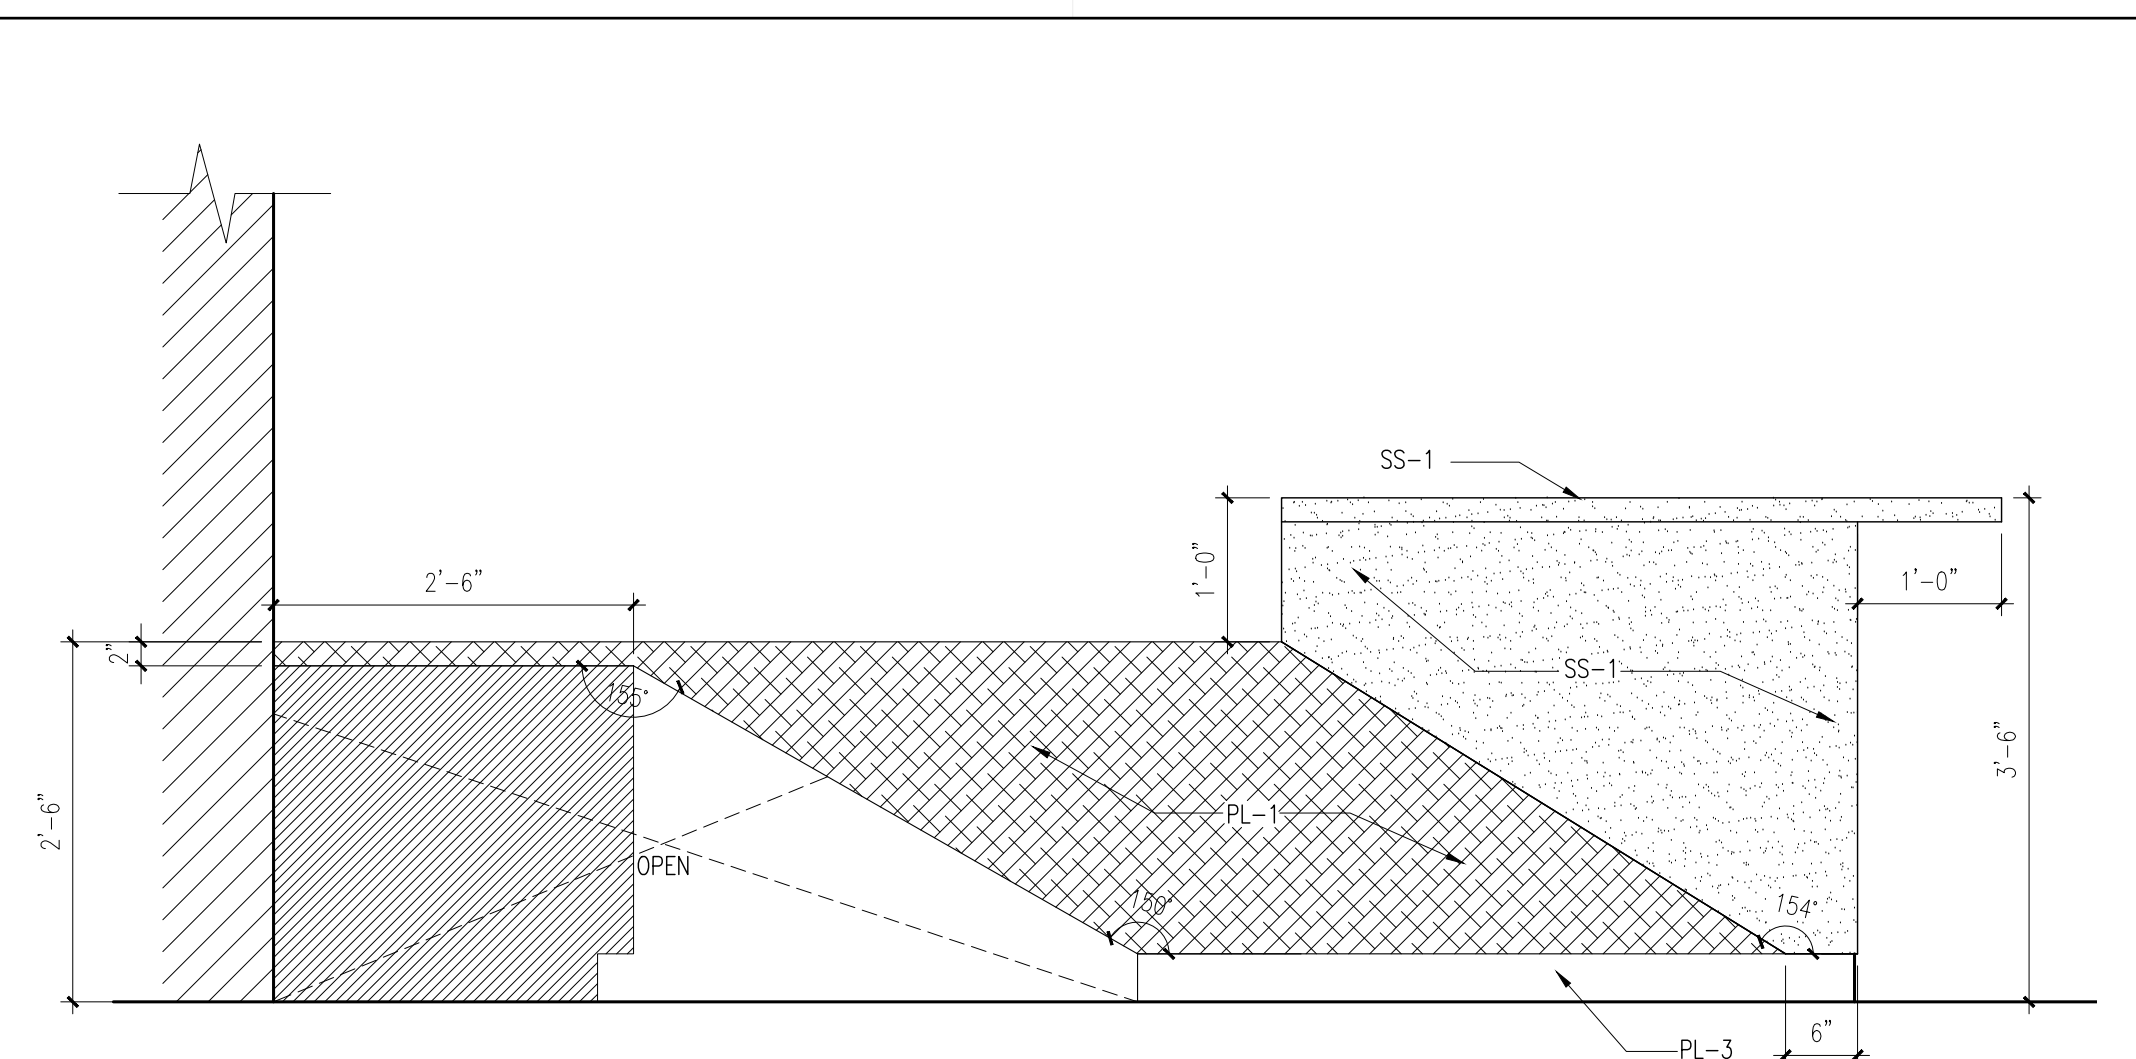


3 MEDIA DESK ELEVATION
A-752 Scale: 3/4" = 1'-0"

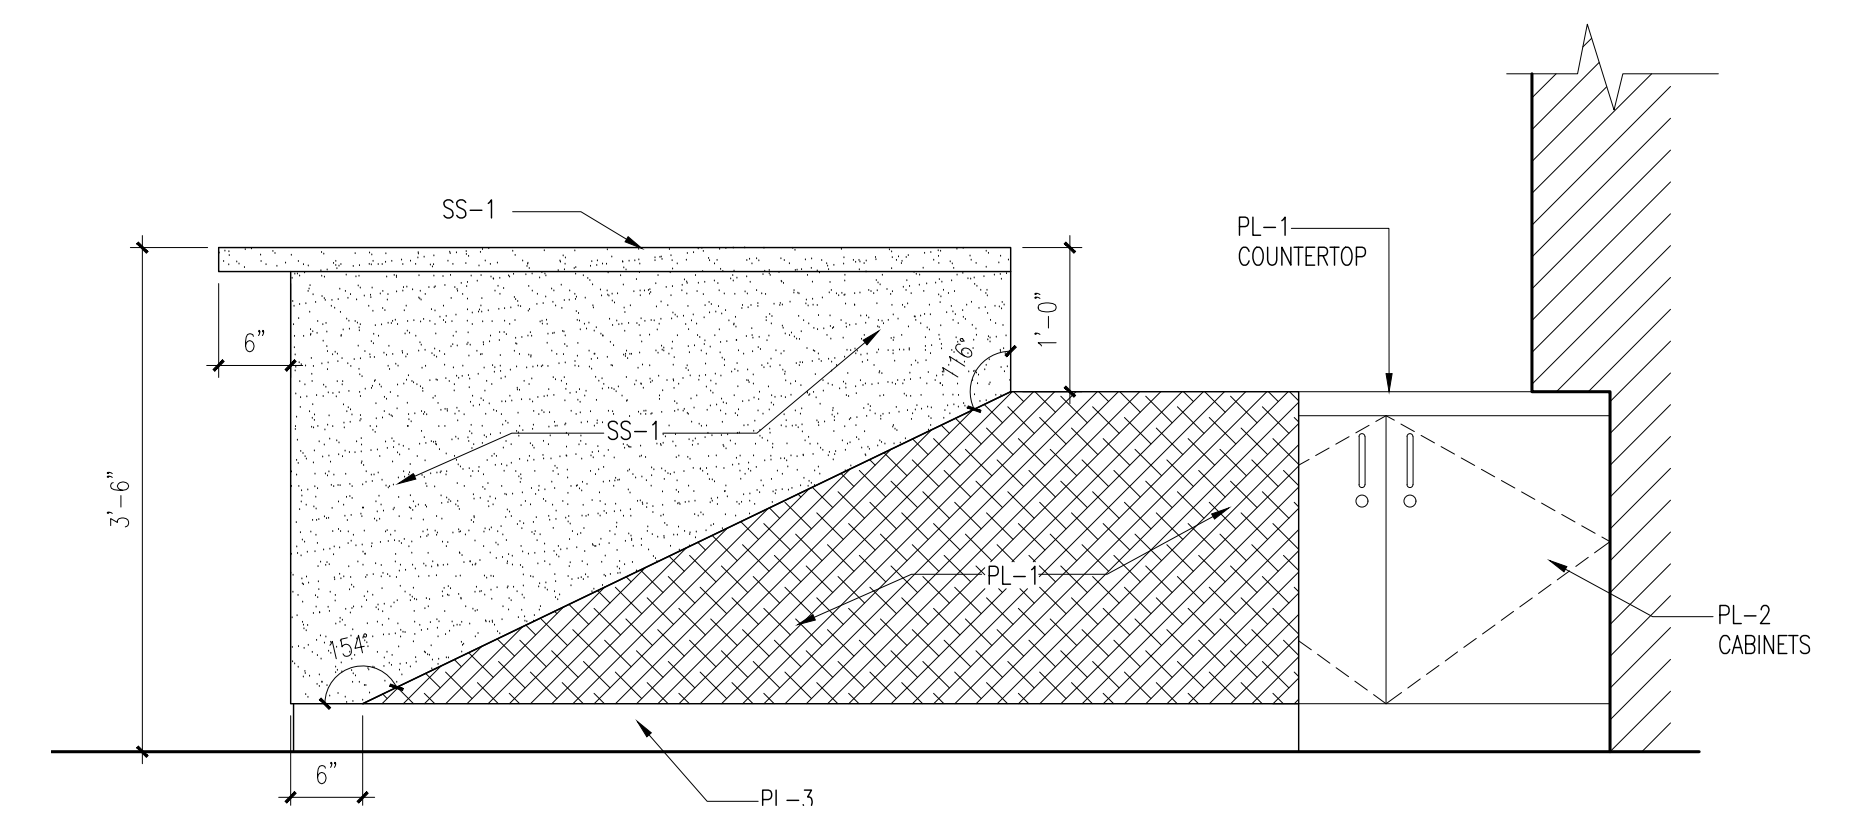


4 MEDIA DESK ELEVATION
A-752 Scale: 3/4" = 1'-0"

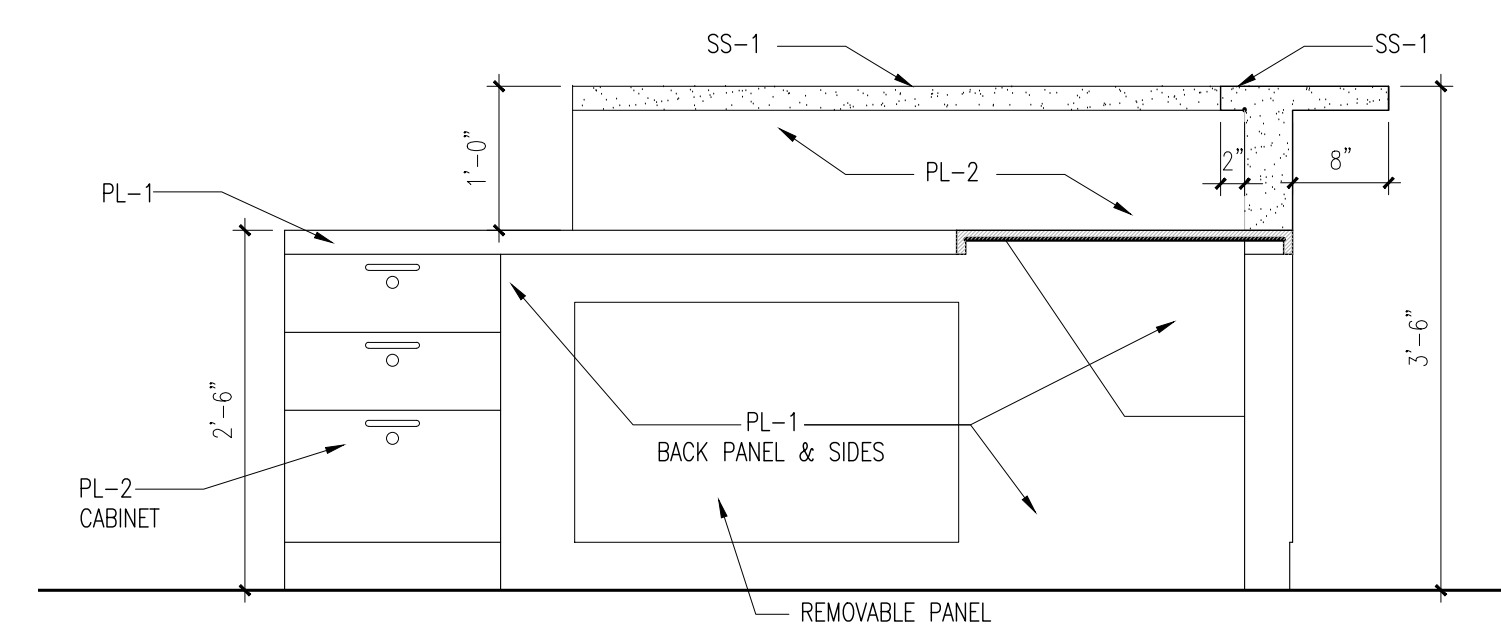


5 MEDIA DESK ELEVATION
A-752 Scale: 3/4" = 1'-0"

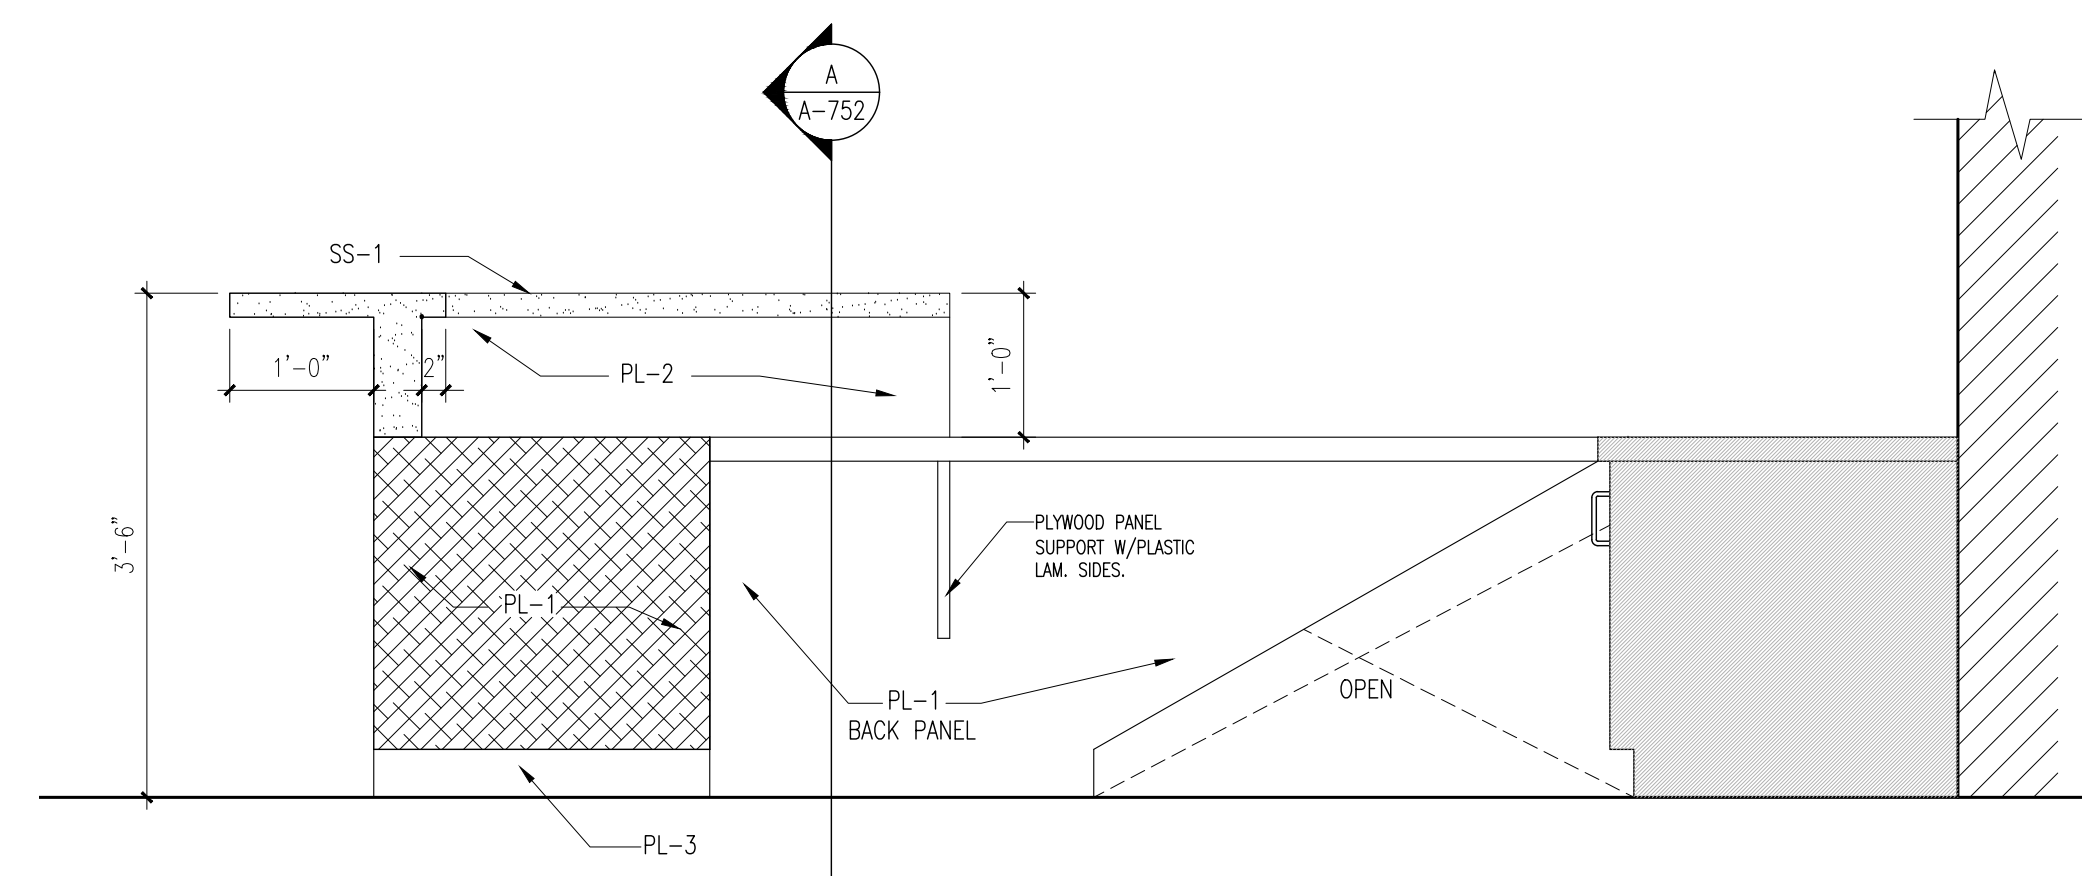


6 MEDIA DESK ELEVATION
A-752 Scale: 3/4" = 1'-0"

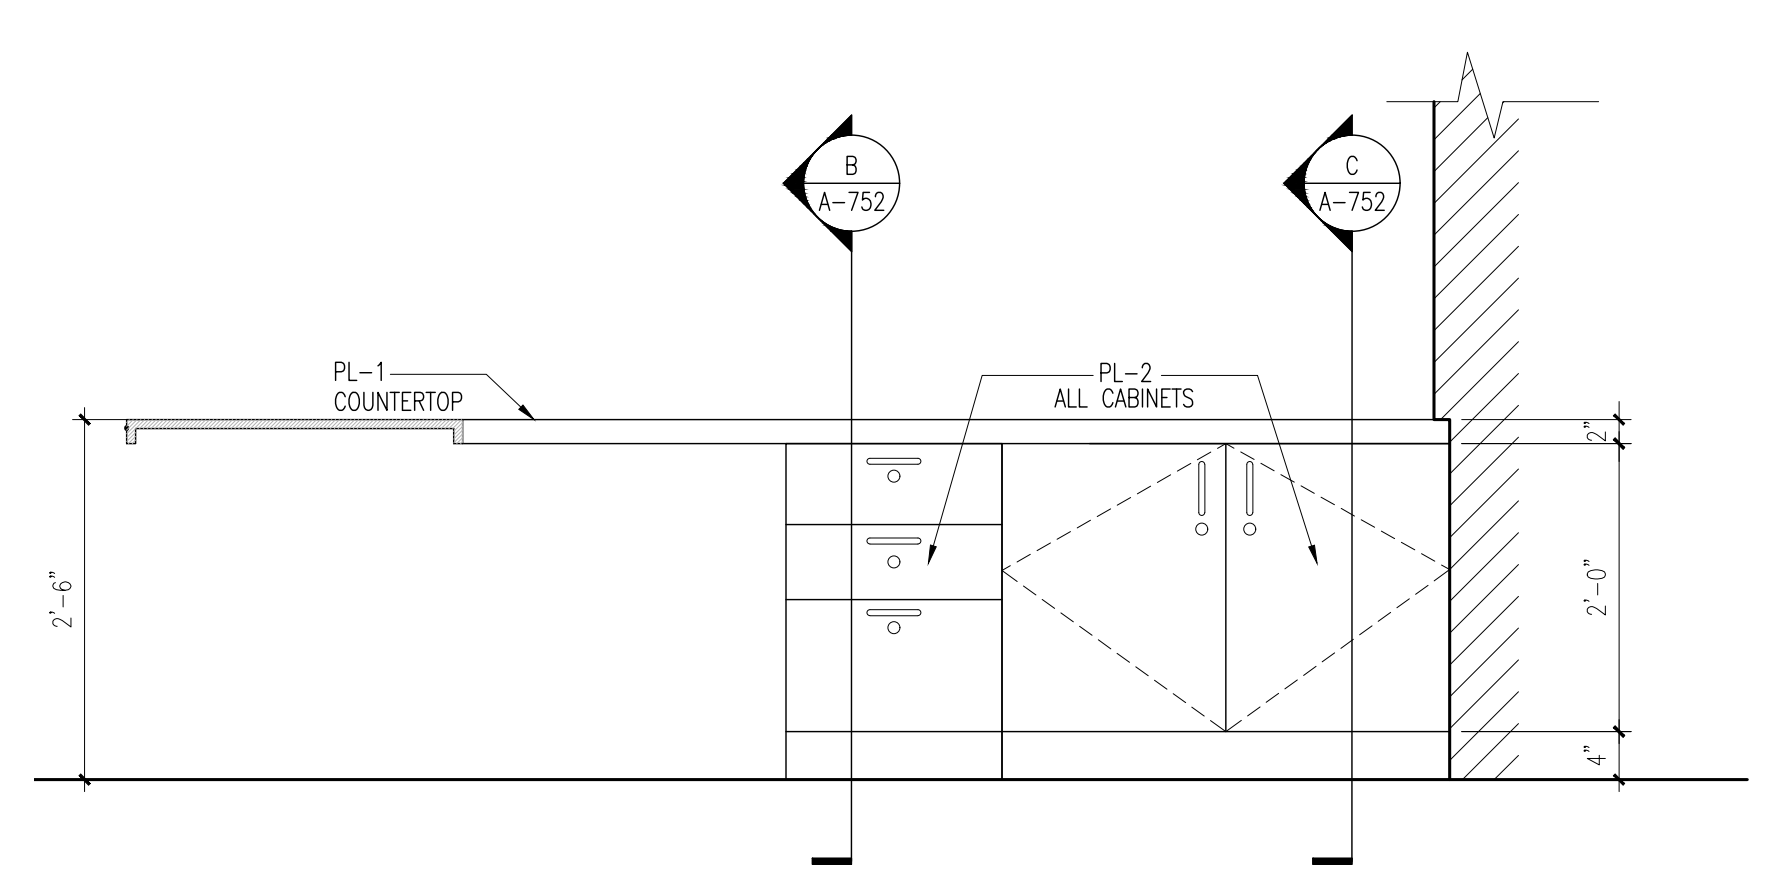


7 MEDIA DESK ELEVATION
A-752 Scale: 3/4" = 1'-0"

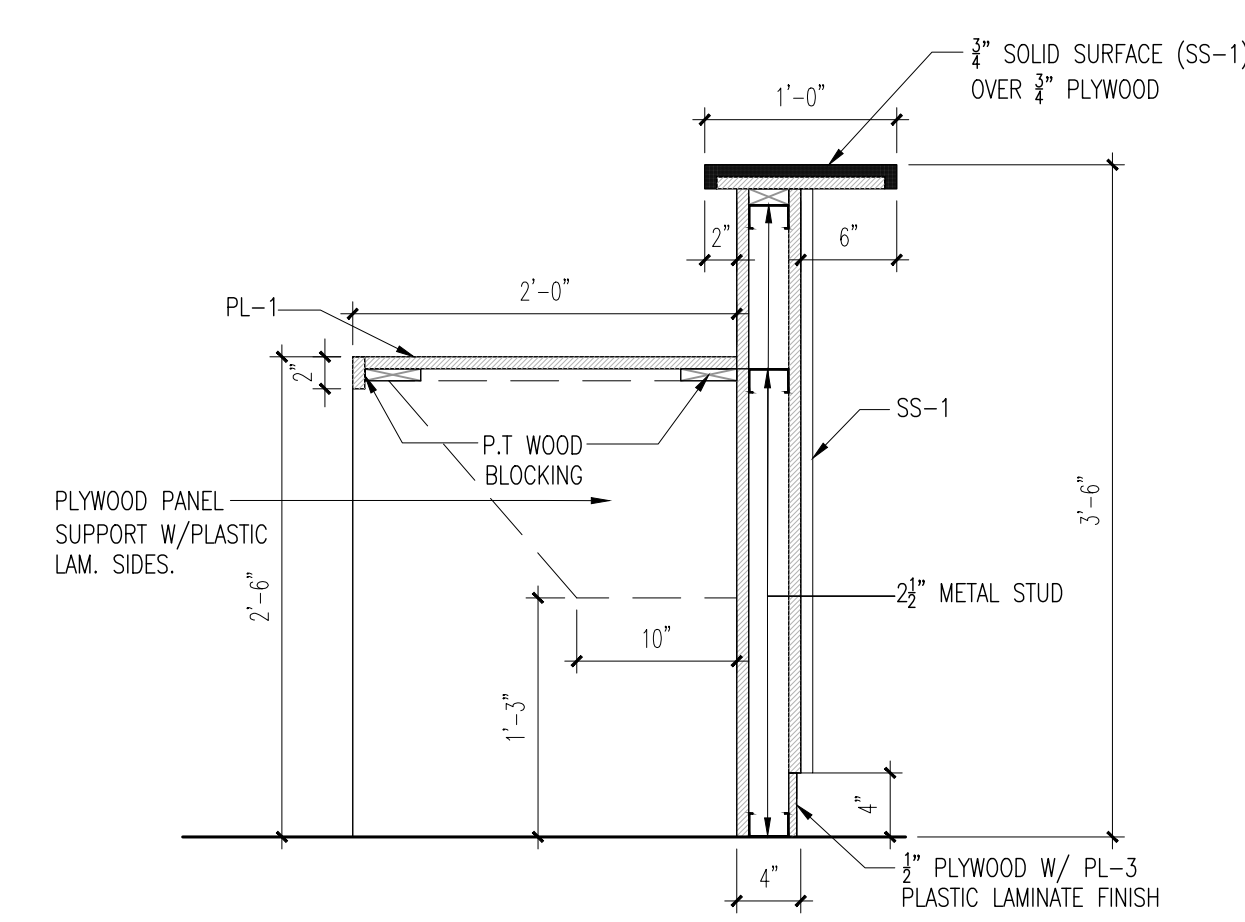

A SECTION DETAIL
A-752 Scale: 1" = 1'-0"

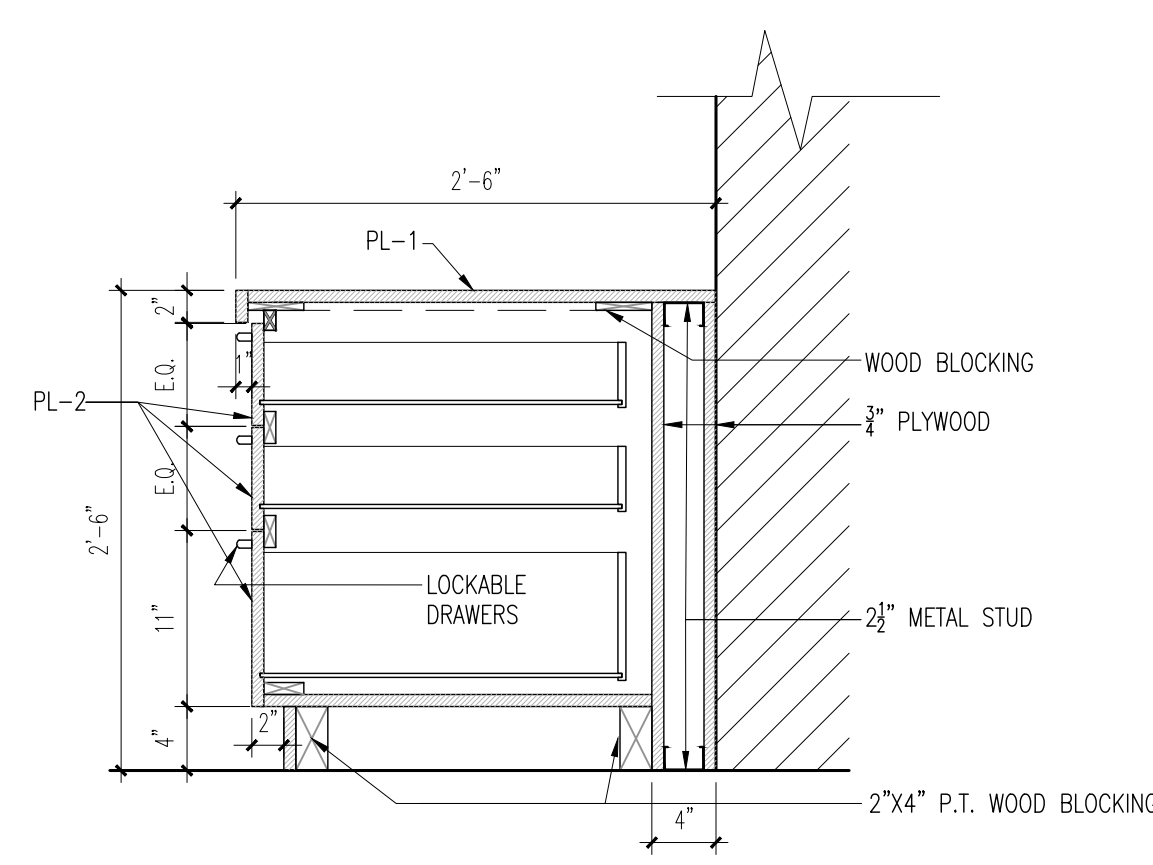

B SECTION DETAIL
A-752 Scale: 1" = 1'-0"

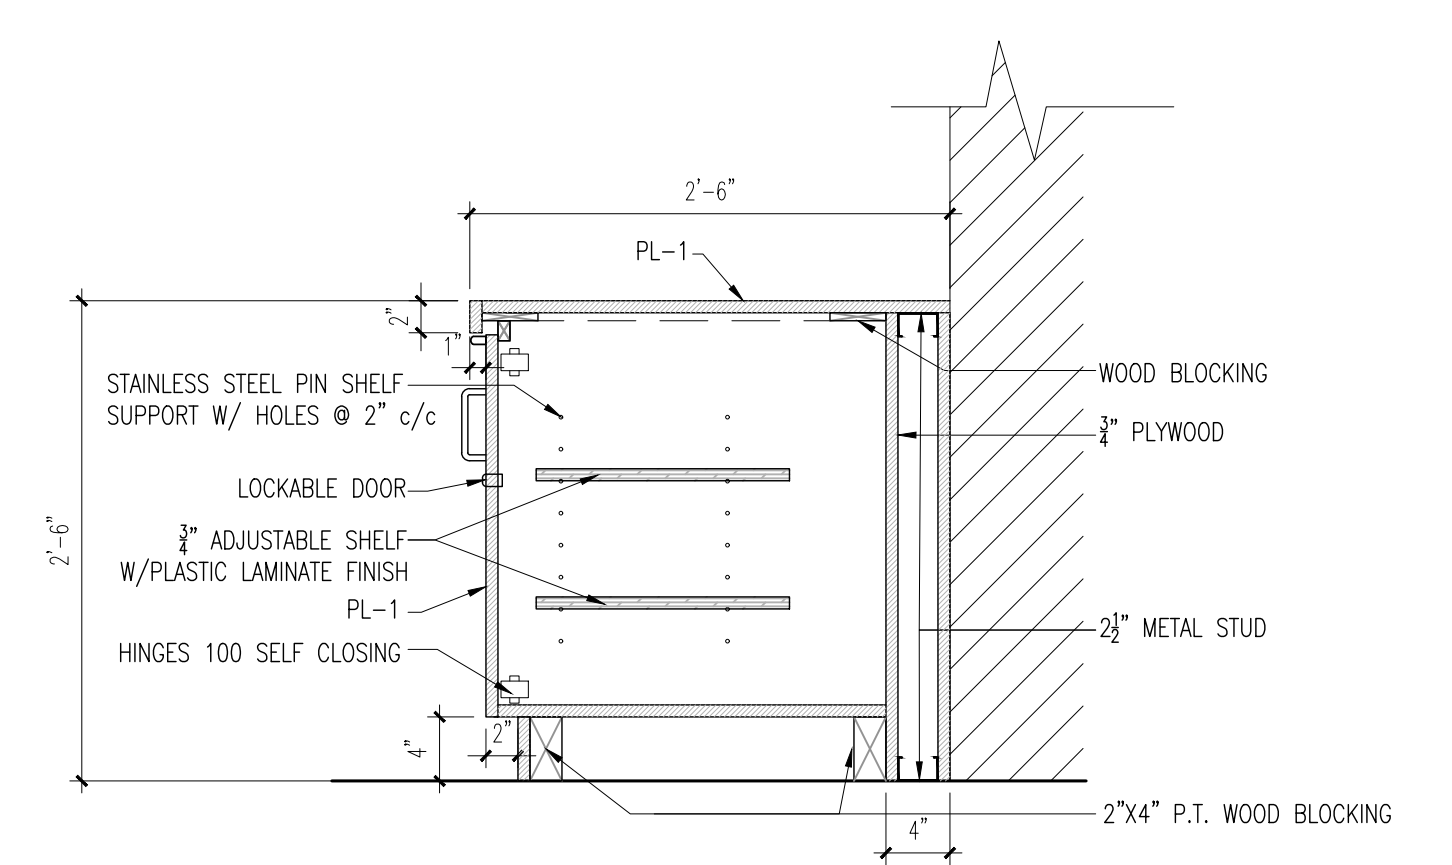

C SECTION DETAIL
A-752 Scale: 1" = 1'-0"

DOOR SCHEDULE - GROUND FLOOR

DOOR NUMBER	ROOM NUMBER	ROOM NAME	SIZE	DOOR				FRAME			JAMB DETAILS	THRESHOLD DETAILS	FIRE LABEL	HARDWARE SET	COMMENTS
				THICKNESS	MATERIAL	FINISH	TYPE	TYPE/STYLE	MATERIAL	FINISH					
1100	1100	ENTRY HALL	PR 3'-6" x 7'-0"	1-3/4"	H.M./GL	PTD	A	K1	H.M.	PTD	T3/A-820	TH-7/A-821	-	01	MISSILE IMPACT; PANIC HARDWARE; CARD ACCESS
1100.1	1100	ENTRY HALL	PR 3'-6" x 7'-0"	1-3/4"	H.M./GL	PTD	B	H-1	H.M.	PTD	P2/A-820	-	45 MIN.	08	PANIC HARDWARE; SECURITY ACCESS
1101.2	1100	CORRIDOR (SOUTHWEST)	PR 3'-0" x 7'-0"	1-3/4"	H.M.	PTD	A	2	H.M.	PTD	T2/A-820	TH-7/A-821	-	02	MISSILE IMPACT; PANIC HARDWARE; CARD ACCESS
1100.3	1100	CORRIDOR	PR 3'-0" x 7'-0"	1-3/4"	H.M.	PTD	C	1	H.M.	PTD	P2/A-820	-	-	09	PANIC HARDWARE
1100.4	1100	CORRIDOR (NORTHWEST)	4'-0" x 7'-0"	1-3/4"	H.M.	PTD	C	1	H.M.	PTD	T4/A-820	TH-2/A-821	-	06	MISSILE IMPACT; PANIC HARDWARE; CARD ACCESS
1100.5	1100	EXTENDED LEARNING AREA	PR 3'-0" x 7'-0"	1-3/4"	H.M.	PTD	E	2	H.M.	PTD	PS/A-820	-	45 MIN.	07	PANIC HARDWARE; DOUBLE SWINGING
1100.6	1100	EXTENDED LEARNING AREA	PR 3'-0" x 7'-0"	1-3/4"	H.M.	PTD	A	2	H.M.	PTD	T3/A-820	TH-7/A-821	-	02	MISSILE IMPACT; PANIC HARDWARE; CARD ACCESS
1100B	1100B	STAIR #2	3'-6" x 7'-0"	1-3/4"	H.M.	PTD	D	1	H.M.	PTD	T3/A-820	-	60 MIN.	05	PANIC HARDWARE
1100B.1	1100B	STAIR #2	PR 3'-0" x 7'-0"	1-3/4"	H.M.	PTD	D	2	H.M.	PTD	T1/A-820	TH-7/A-821	-	03	MISSILE IMPACT; PANIC HARDWARE
1100C	1100C	STAIR #3	PR 3'-0" x 7'-0"	1-3/4"	H.M.	PTD	D	2	H.M.	PTD	T3/A-820	TH-4/A-821	60 MIN.	10	ONE DOOR SWINGS 180°
1100C.1	1100C	STAIR #3	PR 3'-0" x 7'-0"	1-3/4"	H.M.	PTD	D	2	H.M.	PTD	T1/A-820	TH-6/A-821	-	03	MISSILE IMPACT; PANIC HARDWARE; ONE DOOR SWINGS 180°
1101.1	1101	RECEPTION	3'-0" x 7'-0"	1-3/4"	H.M./GL	PTD	B	H-2	H.M.	PTD	-	-	45 MIN.	13	DOOR SWINGS 180°; SECURITY ACCESS
1101.2	1101	RECEPTION	3'-0" x 7'-0"	1-3/4"	H.M./GL	PTD	B	H-2	H.M.	PTD	-	-	-	12	DOOR SWINGS 180°; SECURITY ACCESS
1101A	1101A	VAULT / STUDENTS RECORDS	3'-0" x 7'-0"	1-3/4"	H.M.	PTD	C	1	H.M.	PTD	P1/A-820	-	45 MIN.	21	
1101B	1101B	CONFERENCE ROOM	3'-0" x 7'-0"	1-3/4"	H.M.	PTD	E	1	H.M.	PTD	P1/A-820	-	-	18	
1101C	1101C	ADMINISTRATIVE OFFICE	3'-0" x 7'-0"	1-3/4"	H.M.	PTD	E	1	H.M.	PTD	P1/A-820	-	-	18	
1101D	1101D	PRINCIPAL OFFICE	3'-0" x 7'-0"	1-3/4"	H.M.	PTD	E	1	H.M.	PTD	P1/A-820	-	-	18	
1101E	1101E	AP OFFICE	3'-0" x 7'-0"	1-3/4"	H.M.	PTD	E	1	H.M.	PTD	P1/A-820	-	-	18	
1101F	1101F	TOILET	3'-0" x 7'-0"	1-3/4"	H.M.	PTD	C	1	H.M.	PTD	P1/A-820	TH-1/A-821	-	16	DOOR SWINGS 180°; 1" UNDERCUT
1101H	1101H	EQUIPMENT STORAGE	3'-0" x 7'-0"	1-3/4"	H.M.	PTD	C	1	H.M.	PTD	P1/A-820	TH-4/A-821	-	20	
1101J	1101J	SECRETARIAL SPACE	3'-0" x 7'-0"	1-3/4"	H.M.	PTD	E	1	H.M.	PTD	P1/A-820	-	-	19	DOOR SWINGS 180°
1102	1102	AMU CLOSET	3'-0" x 7'-0"	1-3/4"	H.M.	PTD	C	1	H.M.	PTD	P1/A-820	TH-4/A-821	-	19	DOOR SWINGS 180°
1103	1103	STUDENT SERVICES RECEPTION	3'-0" x 7'-0"	1-3/4"	ALUM/ML	PTD	A	IS-1	ALUM	PTD	P1/A-820	-	-	11	DOOR SWINGS 180°
1103.1	1103	STUDENT SERVICES RECEPTION	3'-0" x 7'-0"	1-3/4"	H.M.	PTD	E	1	H.M.	PTD	P1/A-820	-	-	19	
1103A	1103A	CLINIC	3'-0" x 7'-0"	1-3/4"	H.M.	PTD	F	5	H.M.	PTD	P1/A-820	-	-	19	
1103B	1103B	CLINIC TOILET	3'-0" x 7'-0"	1-3/4"	H.M.	PTD	C	1	H.M.	PTD	P1/A-820	TH-1/A-821	-	16	1" UNDERCUT
1103D	1103D	GUIDANCE COUNSELOR OFFICE	3'-0" x 7'-0"	1-3/4"	H.M.	PTD	E	1	H.M.	PTD	P1/A-820	-	-	19	
1103E	1103E	GUIDANCE COUNSELOR OFFICE	3'-0" x 7'-0"	1-3/4"	H.M.	PTD	E	1	H.M.	PTD	P1/A-820	-	-	19	
1103F	1103F	STORAGE	3'-0" x 7'-0"	1-3/4"	H.M.	PTD	C	1	H.M.	PTD	P1/A-820	-	-	20	
1103G	1103G	STAFF TOILET	3'-0" x 7'-0"	1-3/4"	H.M.	PTD	C	1	H.M.	PTD	P1/A-820	TH-1/A-821	-	16	1" UNDERCUT
1103H	1103H	BOOKKEEPING OFFICE	3'-0" x 7'-0"	1-3/4"	H.M.	PTD	E	1	H.M.	PTD	P1/A-820	-	-	19	
1103J	1103J	ITINERANT OFFICE	3'-0" x 7'-0"	1-3/4"	H.M.	PTD	E	1	H.M.	PTD	P1/A-820	-	-	19	
1104.1	1104	MUSIC LAB	3'-0" x 7'-0"	1-3/4"	H.M.	PTD	E	1	H.M.	PTD	P1/A-820	-	45 MIN.	19	PANIC HARDWARE
1104.2	1104	MUSIC LAB	3'-0" x 7'-0"	1-3/4"	H.M.	PTD	E	1	H.M.	PTD	P1/A-820	-	45 MIN.	19	PANIC HARDWARE
1104.3	1104	MUSIC LAB	(6) 3'-0" x 8'-0"	1-3/4"	ALUM/ML	PREFIN.	H	-	ALUM	PTD	-	-	-	22	SLIDING GLASS DOOR SYSTEM
1104A	1104A	STORAGE	3'-0" x 7'-0"	1-3/4"	H.M.	PTD	C	1	H.M.	PTD	P1/A-820	TH-4/A-821	45 MIN.	22	DOOR SWINGS 180° ONLY
1105	1105	ELECTRICAL ROOM	3'-0" x 7'-0"	1-3/4"	H.M.	PTD	C	1	H.M.	PTD	P1/A-820	TH-4/A-821	-	20	DOOR SWINGS 180°
1106	1106	CUSTODIAL	3'-0" x 7'-0"	1-3/4"	H.M.	PTD	C	1	H.M.	PTD	P1/A-820	TH-4/A-821	-	20	
1107	1107	TEACHER DINING	3'-0" x 7'-0"	1-3/4"	H.M.	PTD	E	1	H.M.	PTD	P1/A-820	-	45 MIN.	19	
1108	1108	KINDERGARTEN CLASSROOM	3'-0" x 7'-0"	1-3/4"	H.M.	PTD	E	1	H.M.	PTD	P1/A-820	-	45 MIN.	19	
1109.1	1109	VESTIBULE	3'-0" x 7'-0"	1-3/4"	H.M.	PTD	E	1	H.M.	PTD	P1/A-820	-	-	15	1" UNDERCUT
1109.2	1109	VESTIBULE	3'-0" x 7'-0"	1-3/4"	H.M.	PTD	E	1	H.M.	PTD	P1/A-820	-	-	15	1" UNDERCUT
1109A	1109A	TOILET	3'-0" x 7'-0"	1-3/4"	H.M.	PTD	C	1	H.M.	PTD	P1/A-820	TH-1/A-821	-	16	1" UNDERCUT
1110	1110	KINDERGARTEN CLASSROOM	3'-0" x 7'-0"	1-3/4"	H.M.	PTD	E	1	H.M.	PTD	P1/A-820	-	45 MIN.	19	
1111	1111	DINING/MULTIPURPOSE CORRIDOR (NORTHEAST)	3'-0" x 7'-0"	1-3/4"	H.M.	PTD	A	1	H.M.	PTD	T3/A-820	TH-7/A-821	-	04	MISSILE IMPACT; PANIC HARDWARE; CARD ACCESS
1111.1	1111	DINING/MULTIPURPOSE CORRIDOR	PR 3'-0" x 7'-0"	1-3/4"	H.M./GL	PTD	B	H-2	H.M.	PTD	-	-	45 MIN.	13	DOOR SWINGS 180°
1111.2	1111	DINING/MULTIPURPOSE CORRIDOR	PR 3'-0" x 7'-0"	1-3/4"	H.M./GL	PTD	B	H-2	H.M.	PTD	-	-	45 MIN.	13	DOOR SWINGS 180°
1112.1	1112	CUSTODIAL RECEIVING	6'-0" x 8'-0"	1-3/4"	GALV	PTD	J	-	GALV	PTD	OH-1/A-820	TH-2/A-821	-	-	OVERHEAD COILING DOOR; MISSILE IMPACT DOOR
1112.2	1112	CUSTODIAL RECEIVING	PR 3'-0" x 7'-0"	-	GALV	GALV	K	-	GALV	GALV	-	-	-	-	CHAINLINK FENCE GATE W/ LOCK
1112.3	1112	VESTIBULE	3'-0" x 7'-0"	1-3/4"	H.M.	PTD	E	1	H.M.	PTD	P1/A-820	TH-4/A-821	45 MIN.	20	1" UNDERCUT (DOOR SWINGS 180° WITH EXTENDED HINGE)
1112A	1112A	TOILET	3'-0" x 7'-0"	1-3/4"	H.M.	PTD	E	1	H.M.	PTD	T3/A-820	TH-6/A-821	-	17	
1114	1114	MAIN ELECTRICAL ROOM	PR 3'-0" x 7'-0"	1-3/4"	H.M.	PTD	C	4	H.M.	PTD	T3/A-820	TH-6/A-821	-	06	MISSILE IMPACT; PANIC HARDWARE; DOOR SWINGS 180°
1115	1115	FLAMMABLE STORAGE	PR 3'-0" x 7'-0"	1-3/4"	H.M.	PTD	C	1	H.M.	PTD	T3/A-820	TH-6/A-821	45 MIN.	06	MISSILE IMPACT; DOOR SWINGS 180°
1115A	1115A	ROOF ACCESS	4'-0" x 7'-0"	1-3/4"	H.M.	PTD	C	1	H.M.	PTD	T4/A-820	TH-2/A-821	-	06	MISSILE IMPACT; DOOR SWINGS 180°
1116.1	1116	KITCHEN/FOOD PREP AREA	3'-0" x 7'-0"	1-3/4"	H.M.	PTD	G	1	H.M.	PTD	T5/A-820	TH-8/A-821	45 MIN.	19	DOOR SWINGS 180°
1116.2	1116	KITCHEN/FOOD PREP AREA	3'-0" x 7'-0"	1-3/4"	H.M.	PTD	G	1	H.M.	PTD	T5/A-820	TH-8/A-821	45 MIN.	19	DOOR SWINGS 180°
1116.3	1116	KITCHEN/FOOD PREP AREA	3'-0" x 7'-0"	1-3/4"	H.M.	PTD	G	1	H.M.	PTD	T5/A-820	TH-8/A-821	45 MIN.	19	DOOR SWINGS 180°
1116.4	1116	KITCHEN/FOOD PREP AREA	3'-0" x 7'-0"	1-3/4"	H.M.	PTD	G	1	H.M.	PTD	T5/A-820	TH-8/A-821	45 MIN.	19	DOOR SWINGS 180°
1116.5	1116	KITCHEN RECEIVING	4'-0" x 7'-0"	1-3/4"	H.M.	PTD	C	1	H.M.	PTD	T4/A-820	TH-2/A-821	-	06	MISSILE IMPACT; CARD ACCESS
1116A	1116A	FOODSERVICE OFFICE	3'-0" x 7'-0"	1-3/4"	H.M.	PTD	F	1	H.M.	PTD	P1/A-820	-	-	19	
1116B	1116B	LAUNDRY	3'-0" x 7'-0"	1-3/4"	H.M.	PTD	C	1	H.M.	PTD	P1/A-820	-	-	20	
1116C	1116C	STAFF TOILET	3'-0" x 7'-0"	1-3/4"	H.M.	PTD	C	1	H.M.	PTD	P1/A-820	TH-8/A-821	-	16	1" UNDERCUT
1116D	1116D	STAFF TOILET	3'-0" x 7'-0"	1-3/4"	H.M.	PTD	C	1	H.M.	PTD	P1/A-820	TH-8/A-821	-	16	1" UNDERCUT
1116E	1116E	DRY STORAGE	3'-0" x 7'-0"	1-3/4"	H.M.	PTD	C	1	H.M.	PTD	P1/A-820	-	-	21	
1117	1117	PRIMARY CLASSROOM	3'-0" x 7'-0"	1-3/4"	H.M.	PTD	E	1	H.M.	PTD	P1/A-820	-	45 MIN.	19	
1117A	1117A	P.E. STORAGE	4'-0" x 7'-0"	1-3/4"	H.M.	PTD	C	1	H.M.	PTD	T3/A-820	TH-6/A-821	-	06.1	MISSILE IMPACT
1118	1118	ART LAB	3'-0" x 7'-0"	1-3/4"	H.M.	PTD	E	1	H.M.	PTD	T5/A-820	-	45 MIN.	19	DOOR SWINGS 180° WITH EXTENDED HINGE
1118A	1118A	ART LAB STORAGE	3'-0" x 7'-0"	1-3/4"	H.M.	PTD	C	1	H.M.	PTD	P1/A-820	TH-4/A-821	-	20	
1119	1119	PRIMARY CLASSROOM	3'-0" x 7'-0"	1-3/4"	H.M.	PTD	E	1	H.M.	PTD	T5/A-820	-	45 MIN.	19	DOOR SWINGS 180° WITH EXTENDED HINGE
1120	1120	VESTIBULE	3'-0" x 7'-0"	1-3/4"	H.M.	PTD	E	1	H.M.	PTD	P1/A-820	TH-1/A-821	-	14	DOOR SWINGS 180°
1120A	1120A	BOYS RESTROOM	3'-0" x 7'-0"	1-3/4"	H.M.	PTD	C	1	H.M.	PTD	P1/A-820	TH-1/A-821	-	14	1" UNDERCUT; DOOR SWINGS 180°
1120B	1120B	GIRL'S RESTROOM	3'-0" x 7'-0"	1-3/4"	H.M.	PTD	C	1	H.M.	PTD	P1/A-820	TH-1/A-821	-	14	1" UNDERCUT
1121	1121	MDF ROOM	3'-0" x 7'-0"	1-3/4"	H.M.	PTD	C	1	H.M.	PTD	P1/A-820	TH-4/A-821	-	22	DOOR SWINGS 180°
1122.1	1122	READING ROOM / STACKS	3'-0" x 7'-0"	1-3/4"	ALUM/ML	ANOD.	A	IS-2	ALUM	ANOD.	P1/A-820	-	-	11	DOOR SWINGS 180°
1122.2	1122	READING ROOM / STACKS	3'-0" x 7'-0"	1-3/4"	ALUM/ML	ANOD.	A	IS-2	ALUM	ANOD.	P1/A-820	-	-	11	DOOR SWINGS 180°
1122B	1122B	DIR. OFFICE/TECH. PROCESSING/AV STORAGE	3'-0" x 7'-0"	1-3/4"	H.M.	PTD	F	6	H.M.	PTD	P1/A-820	-	-	19	DOOR SWINGS 180°
1124	1124	PRIMARY CLASSROOM	3'-0" x 7'-0"	1-3/4"	H.M.	PTD	E	1	H.M.	PTD	P1/A-820	-	SM- 20 MIN.	19	
1125	1125	KINDERGARTEN CLASSROOM	3'-0" x 7'-0"	1-3/4"	H.M.	PTD	E	1	H.M.	PTD	P1/A-820	-	SM- 20 MIN.	19	
1125A	1125A	TOILET	3'-0" x 7'-0"	1-3/4"	H.M.	PTD	C	1	H.M.	PTD	P1/A-820	TH-1/A-821	-	16	1" UNDERCUT
1126.1	1126	VESTIBULE	3'-0" x 7'-0"	1-3/4"	H.M.	PTD	E	1	H.M.	PTD	P1/A-820	-	-	15	1" UNDERCUT
1126.2	1126	VESTIBULE	3'-0" x 7'-0"	1-3/4"	H.M.	PTD	E	1	H.M.	PTD	P1/A-820	-	-	15	1" UNDERCUT
1126A	1126A	TOILET	3'-0" x 7'-0"	1-3/4"	H.M.	PTD	C	1	H.M.	PTD	P1/A-820	TH-1/A-821	-	16	1" UNDERCUT
1127	1127	PRIMARY CLASSROOM	3'-0" x 7'-0"	1-3/4"	H.M.	PTD	E	1	H.M.	PTD	P1/A-820	-	SM- 20 MIN.	19	
1128	1128	KINDERGARTEN CLASSROOM	3'-0" x 7'-0"	1-3/4"	H.M.	PTD	E	1	H.M.	PTD	P1/A-820	-	SM- 20 MIN.	19	
1129.1	1129	VESTIBULE	3'-0" x 7'-0"	1-3/4"	H.M.	PTD	E	1	H.M.	PTD	P1/A-820	-	-	15	1" UNDERCUT
1129.2	1129	VESTIBULE	3'-0" x 7'-0"	1-3/4"	H.M.	PTD	E	1	H.M.	PTD	P1/A-820	-	-	15	1" UNDERCUT
1129A	1129A	TOILET	3'-0" x 7'-0"	1-3/4"	H.M.	PTD	C	1							

DOOR SCHEDULE - SECOND FLOOR																
DOOR NUMBER	ROOM NUMBER	ROOM NAME	SIZE	DOOR				FRAME			JAMB DETAILS	THRESHOLD DETAILS	FIRE LABEL	HARDWARE SET		COMMENTS
				THICK- NESS	MATERIAL	FINISH	TYPE	TYPE/ STYLE	MATERIAL	FINISH						
1200A	1200A	STAIR #1	PR 3'-0" x 7'-0"	1-3/4"	H.M.	PTD.	D	2	H.M.	PTD	P1/A-820	-	60 MIN.	10		ONE DOOR SWINGS 180"
1200B	1200B	STAIR #2	PR 3'-0" x 7'-0"	1-3/4"	H.M.	PTD.	D	2	H.M.	PTD	T3/A-820	-	60 MIN.	10		ONE DOOR SWINGS 180"
1200C	1200C	STAIR #3	PR 3'-0" x 7'-0"	1-3/4"	H.M.	PTD.	D	2	H.M.	PTD	T3/A-821	-	60 MIN.	10		ONE DOOR SWINGS 180"
1201	1201	PRIMARY CLASSROOM	3'-0" x 7'-0"	1-3/4"	H.M.	PTD.	E	1	H.M.	PTD	P1/A-820	-	SM-20 MIN.	19		
1202	1202	PRIMARY CLASSROOM	3'-0" x 7'-0"	1-3/4"	H.M.	PTD.	E	1	H.M.	PTD	P1/A-820	-	SM-20 MIN.	19		
1203	1203	TEACHER PLANNING	3'-0" x 7'-0"	1-3/4"	H.M.	PTD.	E	1	H.M.	PTD	P1/A-820	-	SM-20 MIN.	19		
1204	1204	INTERMEDIATE CLASSROOM	3'-0" x 7'-0"	1-3/4"	H.M.	PTD.	E	1	H.M.	PTD	P1/A-820	-	SM-20 MIN.	19		
1205	1205	INTERMEDIATE CLASSROOM	3'-0" x 7'-0"	1-3/4"	H.M.	PTD.	E	1	H.M.	PTD	P1/A-820	-	SM-20 MIN.	19		
1206	1206	INTERMEDIATE CLASSROOM	3'-0" x 7'-0"	1-3/4"	H.M.	PTD.	E	1	H.M.	PTD	P1/A-820	-	SM-20 MIN.	19		
1207	1207	PRIMARY CLASSROOM	3'-0" x 7'-0"	1-3/4"	H.M.	PTD.	E	1	H.M.	PTD	P1/A-820	-	SM-20 MIN.	19		
1208	1208	INTERMEDIATE CLASSROOM	3'-0" x 7'-0"	1-3/4"	H.M.	PTD.	E	1	H.M.	PTD	P1/A-820	-	SM-20 MIN.	19		
1209	1209	ELEV. MACHINE ROOM	3'-0" x 7'-0"	1-3/4"	H.M.	PTD.	C	1	H.M.	PTD	P1/A-820	TH-4/A-821	45 MIN.	21		
1210	1210	PRIMARY CLASSROOM	3'-0" x 7'-0"	1-3/4"	H.M.	PTD.	E	1	H.M.	PTD	P1/A-820	-	SM-20 MIN.	19		
1211	1211	NOT USED														
1212	1212	NOT USED														
1213	1213	PRIMARY CLASSROOM	3'-0" x 7'-0"	1-3/4"	H.M.	PTD.	E	1	H.M.	PTD	P1/A-820	-	SM-20 MIN.	19		
1214	1214	INTERMEDIATE CLASSROOM	3'-0" x 7'-0"	1-3/4"	H.M.	PTD.	E	1	H.M.	PTD	P1/A-820	-	SM-20 MIN.	19		
1215	1215	PRIMARY CLASSROOM	3'-0" x 7'-0"	1-3/4"	H.M.	PTD.	E	1	H.M.	PTD	P1/A-820	-	SM-20 MIN.	19		
1216	1216	ELECTRICAL ROOM	3'-0" x 7'-0"	1-3/4"	H.M.	PTD.	C	1	H.M.	PTD	P1/A-820	TH-3/A-821	45 MIN.	23		DOOR SWINGS 180"
1217	1217	DATA ROOM	3'-0" x 7'-0"	1-3/4"	H.M.	PTD.	C	1	H.M.	PTD	P1/A-820	TH-3/A-821	SM-20 MIN.	23		DOOR SWINGS 180"
1218	1218	PRIMARY CLASSROOM	3'-0" x 7'-0"	1-3/4"	H.M.	PTD.	E	1	H.M.	PTD	P1/A-820	-	SM-20 MIN.	19		
1219	1219	INTERMEDIATE CLASSROOM	3'-0" x 7'-0"	1-3/4"	H.M.	PTD.	E	1	H.M.	PTD	P1/A-820	-	SM-20 MIN.	19		
1220	1220	RESOURCE ROOM	3'-0" x 7'-0"	1-3/4"	H.M.	PTD.	E	1	H.M.	PTD	P1/A-820	-	SM-20 MIN.	19		
1221	1221	RESOURCE ROOM	3'-0" x 7'-0"	1-3/4"	H.M.	PTD.	E	1	H.M.	PTD	P1/A-820	-	SM-20 MIN.	19		
1222	1222	PRIMARY CLASSROOM	3'-0" x 7'-0"	1-3/4"	H.M.	PTD.	E	1	H.M.	PTD	P1/A-820	-	SM-20 MIN.	19		
1223	1223	INTERMEDIATE CLASSROOM	3'-0" x 7'-0"	1-3/4"	H.M.	PTD.	E	1	H.M.	PTD	P1/A-820	-	SM-20 MIN.	19		
1224	1224	CUSTODIAL CLOSET	3'-0" x 7'-0"	1-3/4"	H.M.	PTD.	C	1	H.M.	PTD	P1/A-820	TH-3/A-821	SM-20 MIN.	21		DOOR SWINGS 180"
1225	1225	STAFF TOILET	3'-0" x 7'-0"	1-3/4"	H.M.	PTD.	C	1	H.M.	PTD	P1/A-820	TH-1/A-821	SM-20 MIN.	17		1" UNDERCUT
1226	1226	PRIMARY CLASSROOM	3'-0" x 7'-0"	1-3/4"	H.M.	PTD.	E	1	H.M.	PTD	P1/A-820	-	SM-20 MIN.	19		
1227	1227	INTERMEDIATE CLASSROOM	3'-0" x 7'-0"	1-3/4"	H.M.	PTD.	E	1	H.M.	PTD	P1/A-820	-	SM-20 MIN.	19		
1228	1228	PRIMARY CLASSROOM	3'-0" x 7'-0"	1-3/4"	H.M.	PTD.	E	1	H.M.	PTD	P1/A-820	-	SM-20 MIN.	19		
1229	1229	INTERMEDIATE CLASSROOM	3'-0" x 7'-0"	1-3/4"	H.M.	PTD.	E	1	H.M.	PTD	P1/A-820	-	SM-20 MIN.	19		
1230	1230	ELECTRICAL ROOM	3'-0" x 7'-0"	1-3/4"	H.M.	PTD.	C	1	H.M.	PTD	P1/A-820	TH-3/A-821	45 MIN.	23		DOOR SWINGS 180"
1231	1231	PRIMARY CLASSROOM	3'-0" x 7'-0"	1-3/4"	H.M.	PTD.	E	1	H.M.	PTD	P1/A-820	-	SM-20 MIN.	19		
1232	1232	INTERMEDIATE CLASSROOM	3'-0" x 7'-0"	1-3/4"	H.M.	PTD.	E	1	H.M.	PTD	P1/A-820	-	SM-20 MIN.	19		
1233	1233	PRIMARY CLASSROOM	3'-0" x 7'-0"	1-3/4"	H.M.	PTD.	E	1	H.M.	PTD	P1/A-820	-	SM-20 MIN.	19		

FIRE DOOR AND WINDOW TABLE		
REFER: NFPA 80, CURRENT EDITION. APPENDIX (E) FOR DOOR AND WINDOW RATINGS		
LABEL	RATING	WALL TYPE & RATING
A	3-HOUR	4-HOUR WALL SEPARATION RATING
B	2-HOUR	3-HOUR WALL SEPARATION RATING
B	90 MINUTE	2-HOUR WALL SEPARATION RATING
C	45 MINUTE	1-HOUR WALL SEPARATION RATING
D	90 MINUTE	EXTERIOR – SEVERE EXPOSURE TO FIRE
E	45 MINUTE	EXTERIOR – MODERATE EXPOSURE
SMOKE	SM-20 MINUTE	SMOKE PARTITION
SMOKE	SM-45 MINUTE	1-HOUR SMOKE COMPARTMENT
2. TABLE 1-11.4 CLEARANCES (UNDERCUT) TO BOTTOM OF FIRE RATED DOORS (ABBREVIATED VERSION BELOW)		
CLEARANCE BETWEEN BOTTOM OF DOOR AND:		SWINGING DOORS W/ FIRE DOOR OR BUILDERS HARDWARE
A. RAISED NONCOMBUSTIBLE THRESHOLD		3/8" MAX.
B. EXPOSED FLOOR SLAB (NO THRESHOLD)		3/4" MAX.
C. RIGID FLOOR TILE (NON-COMBUSTIBLE)		5/8" FOR BUILDERS HARDWARE ONLY
D. FLOOR COVERINGS (COMBUSTIBLE)		1/2" MAX.
LABEL	RATING	MAX. AREA OF GLAZING
A	3-HOUR	N/A
B	2-HOUR	N/A
B	90 MINUTE	100 SQ. IN.
C	45 MINUTE	1296 SQ. IN.
D	90 MINUTE	100 SQ. IN.
E	45 MINUTE	1296 SQ. IN.
SMOKE	SM-20 MINUTE	1296 SQ. IN.
SMOKE	SM-45 MINUTE	1296 SQ. IN.

NOTE

1. REFER TO SHT. A-800 FOR DOOR ELEVATIONS, FRAME STYLE AND ELEVATIONS.
2. REFER TO SHT. A-820 FOR JAMB DETAILS.
3. REFER TO SHT. A-821 FOR THRESHOLD DETAILS.
4. UNDERCUT FOR NON-RATED DOORS 1" MAX.
5. ALL FIRE RATED DOORS AND FRAMES SHALL BEAR THE LEGIBLE U.L. LABEL.
6. NO WIREGLASS IS PERMITTED PER M-COPI'S STANDARDS AND FBC. ALL GLAZING IN SMOKE DOORS SHALL BE TEMPERED GLASS (20 MIN.). ALL GLAZING IN FIRE-RATED DOORS SHALL BE FIRE RATED GLASS.
7. DOOR ASSEMBLIES IN CORRIDORS AND SMOKE PARTITIONS AND SMOKE BARRIERS SHALL BE IN COMPLIANCE WITH U.L.1784 PER FBC 2010, 715.3.3.


CHECKED BY: LR.		DRAWN BY: C.V.	
--------------------	--	-------------------	--

CONSULTANT INFO:





NEW ELEMENTARY SCHOOL (K-5)
VENETIAN PARC WEST
SOUTHWEST 157th AVENUE and 174th STREET
MIAMI, FL. 33187
MDCPS PROJECT No. 01892600

KEY PLAN

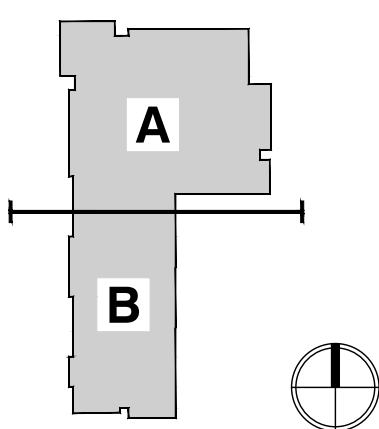


CONSULTANT INFO:

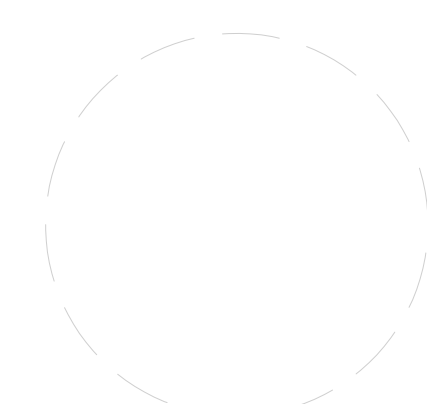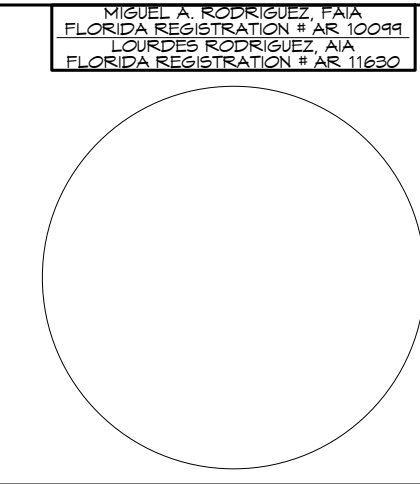

RODRIGUEZ ARCHITECTS, INC.
2121 PONCE DE LEON BLVD. STE. 1010
CORAL GABLES, FL. 33134
TEL: (305) 448-3373
FAX: (305) 448-3374

RODRIGUEZ ARCHITECTS INCORPORATED
2121 PONCE DE LEON BLVD. STE. 1010
CORAL GABLES, FL. 33134
TEL: (305) 448-3373
FAX: (305) 448-3374

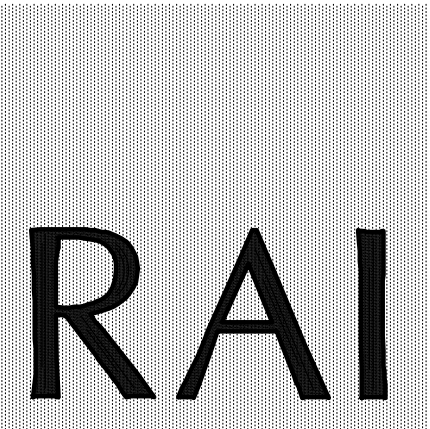


REVISIONS:


DRAWING TITLE:

DOOR SCHEDULE SECOND FLOOR	
SCALE AS NOTED	
ISSUE DATE 12/16/14	PROJECT NO. 1906
SHEET: A-811	


NOTE: ALL DIMENSIONS ON PLANS INDICATING DOOR OPENING DIMENSIONS ARE NOMINAL SIZES. CONTRACTOR SHALL COORDINATE ALL ROUGH OPENINGS REQUIRED WITH JAMB DETAILS SHOWN.

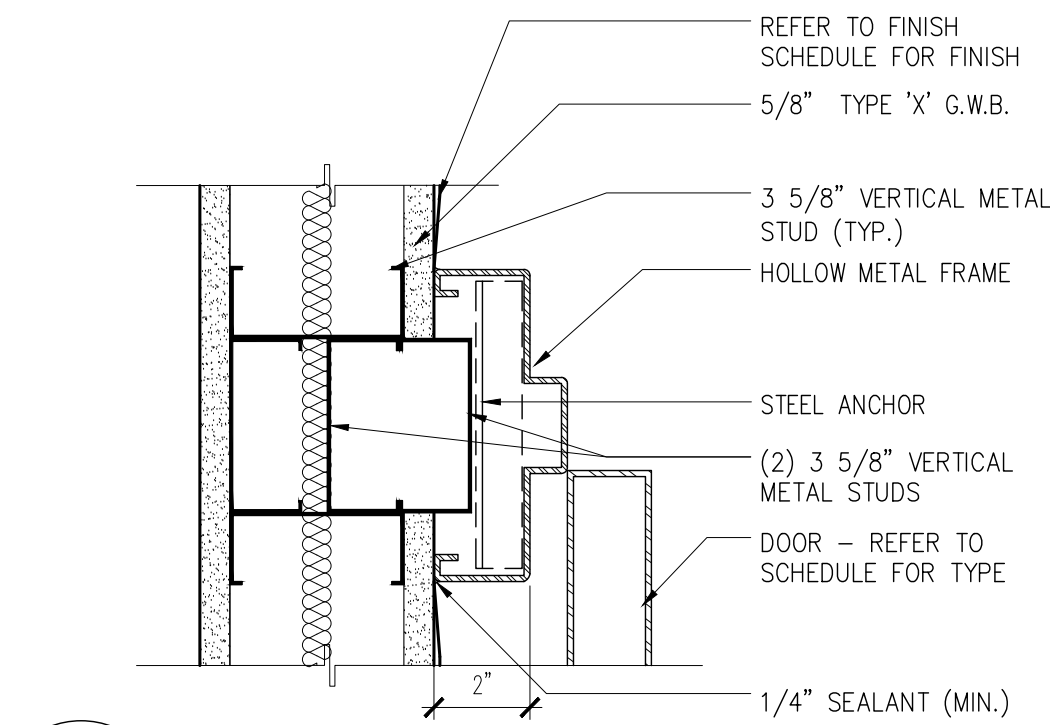


P-5 DOOR JAMB AND HEAD DETAIL
Scale: 3" = 1'-0"

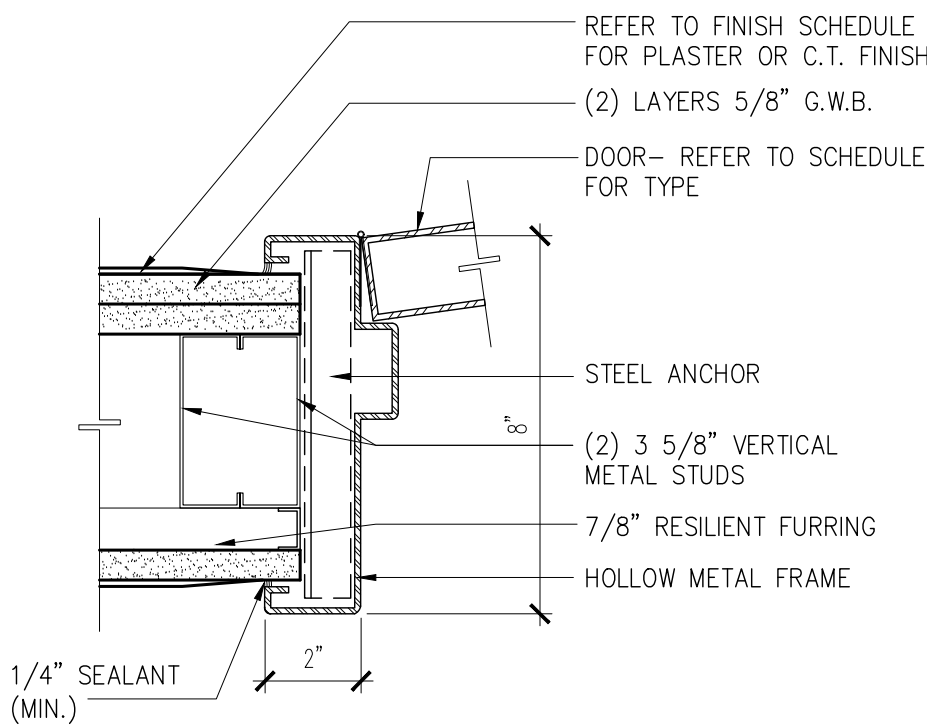


P-4 DOOR JAMB AND HEAD DETAIL
Scale: 3" = 1'-0"

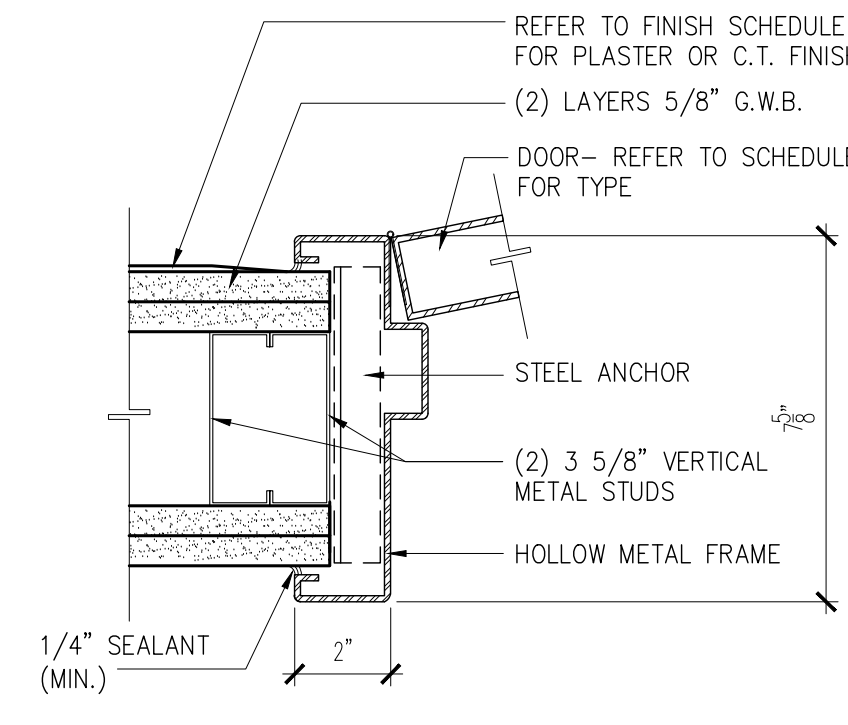


P-3 DOOR JAMB AND HEAD DETAIL
Scale: 3" = 1'-0"

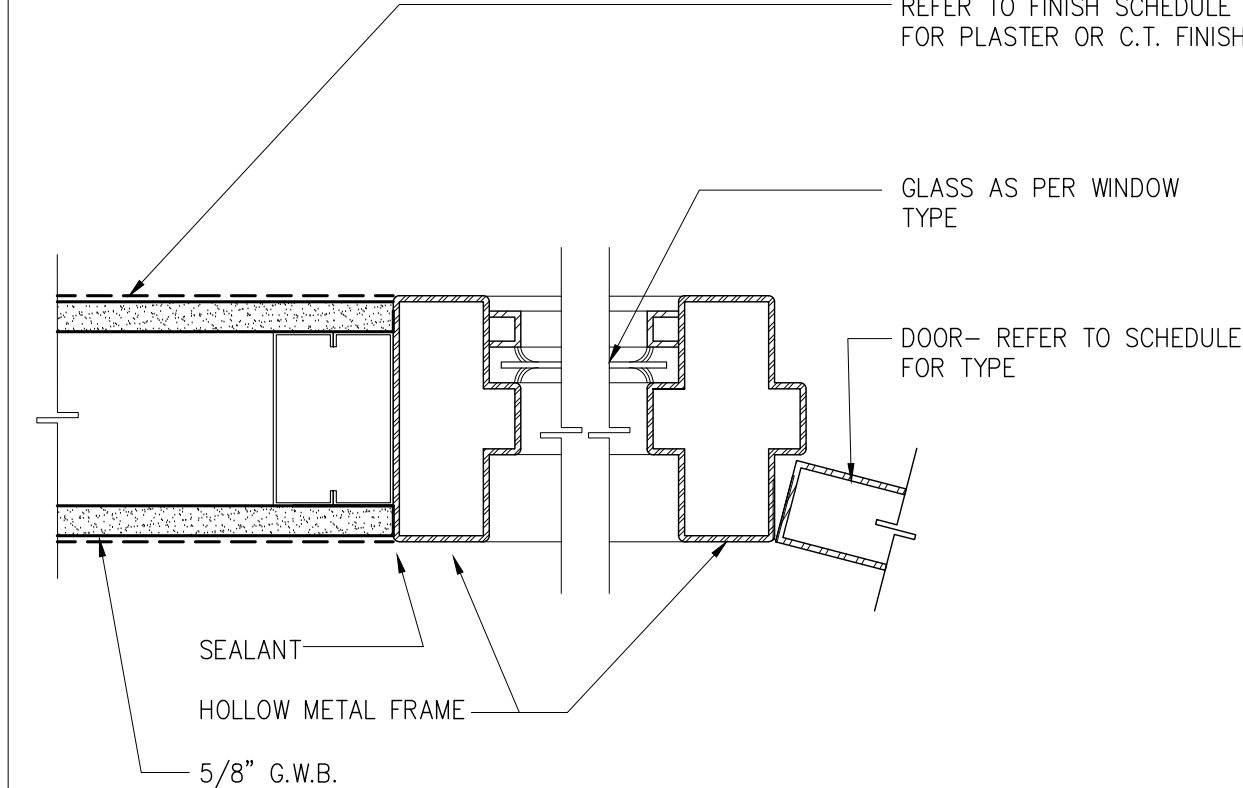


P-2 DOOR JAMB AND HEAD DETAIL
Scale: 3" = 1'-0"

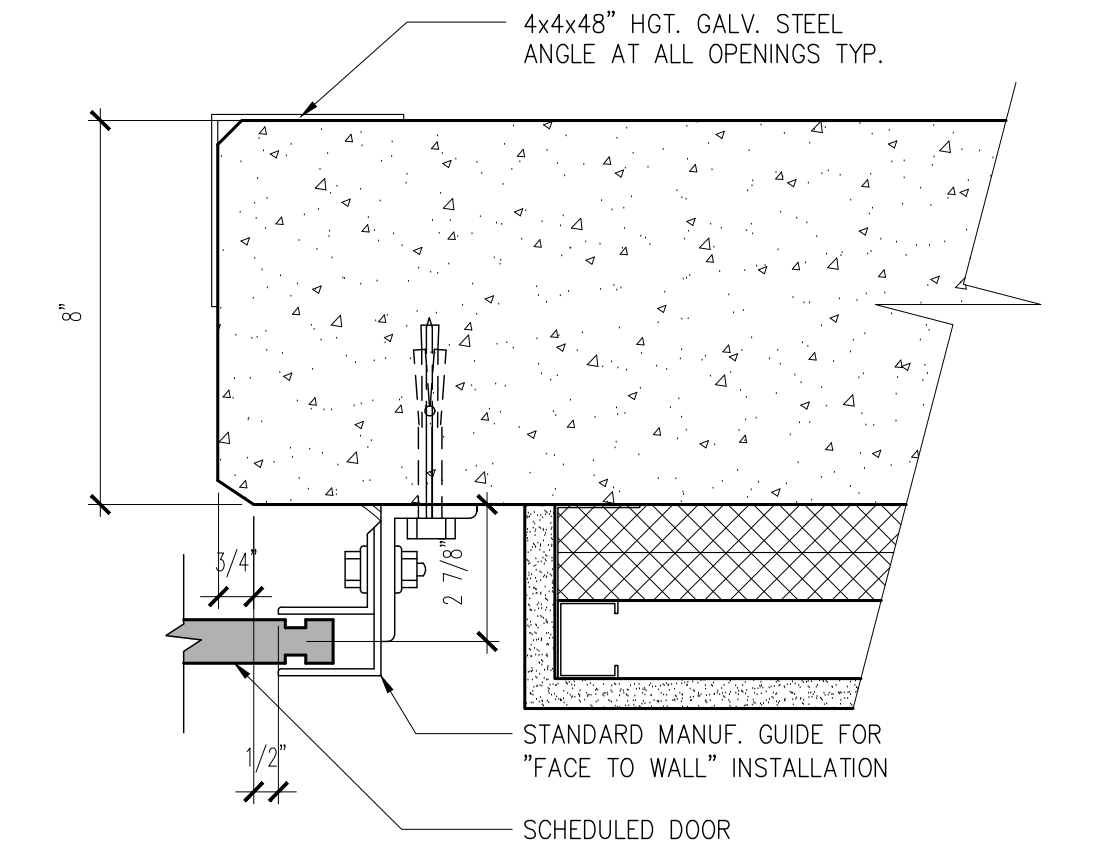


OH-1 OVERHEAD DOOR JAMB DETAIL
Scale: 3" = 1'-0"

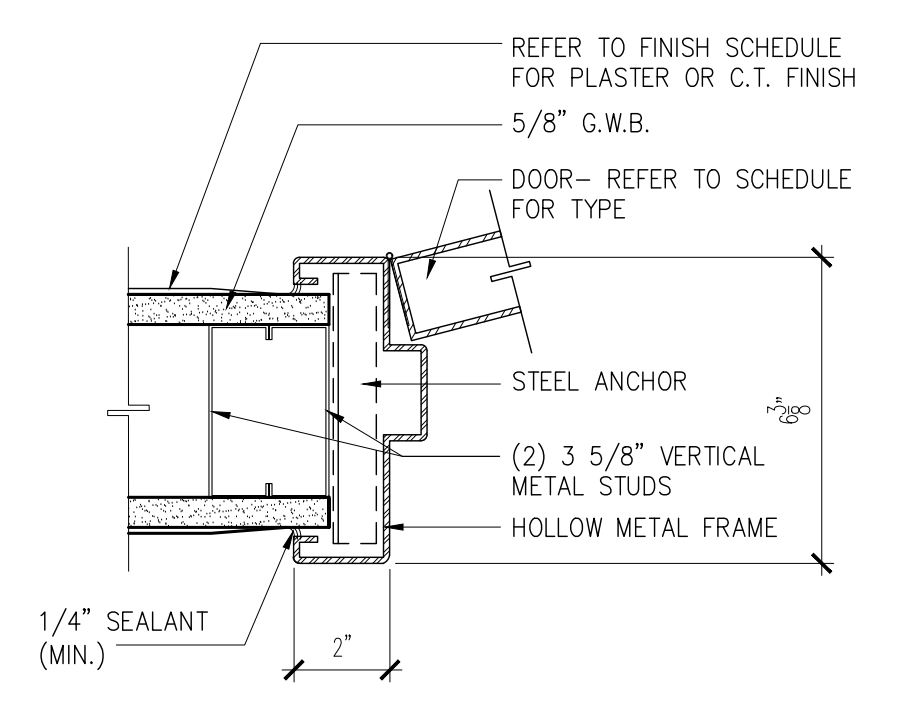


P-1 DOOR JAMB AND HEAD DETAIL
Scale: 3" = 1'-0"

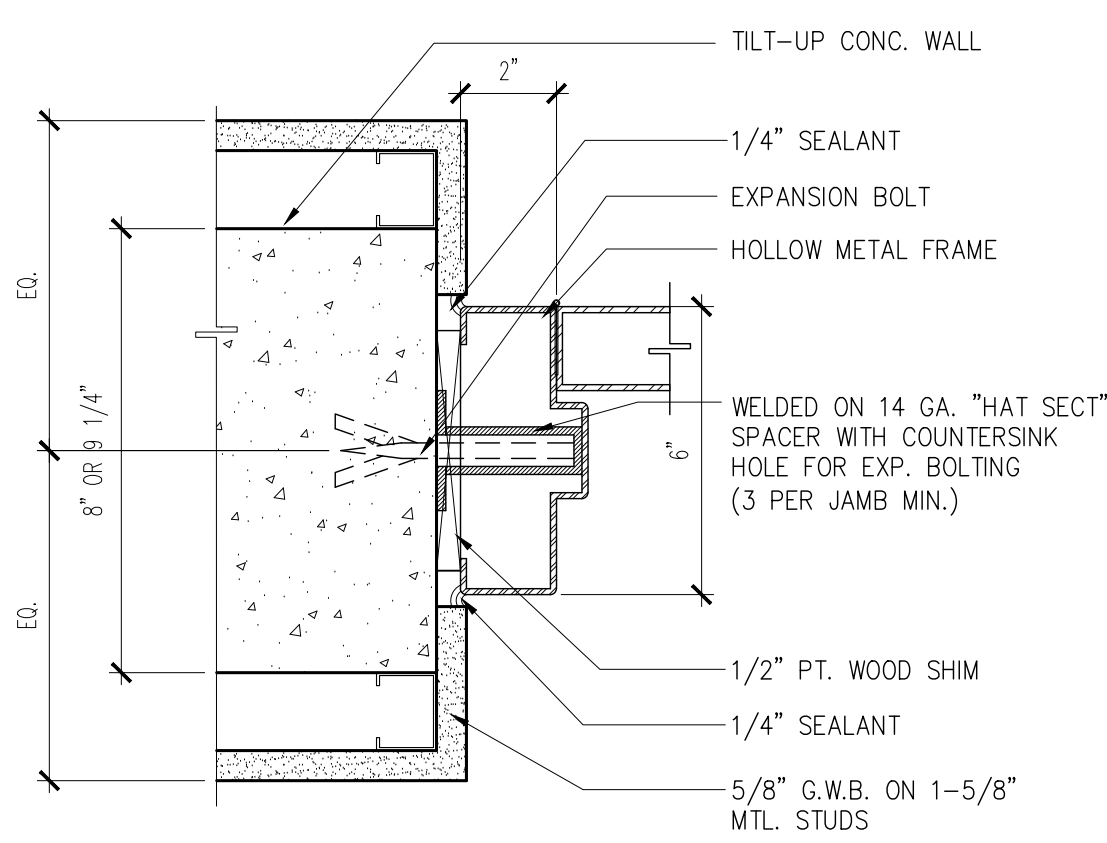


T-5 DOOR JAMB AND HEAD DETAIL
Scale: 3" = 1'-0"

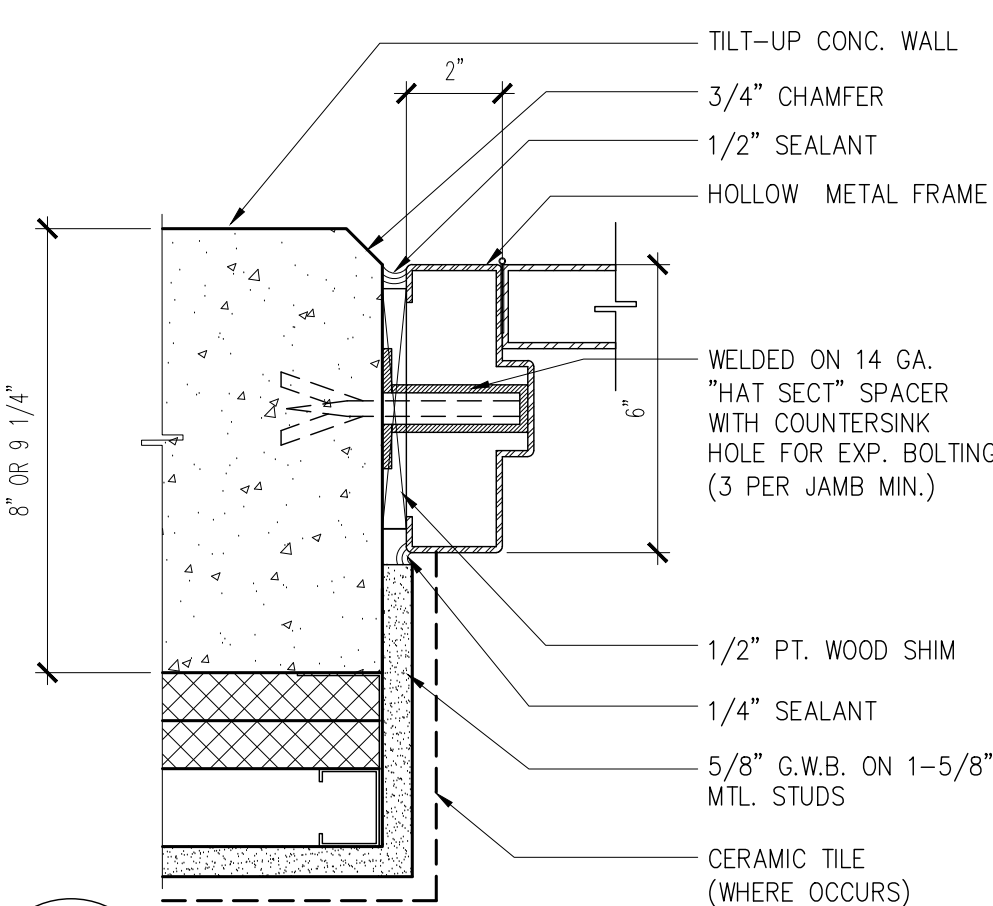


T-4 DOOR JAMB AND HEAD DETAIL
Scale: 3" = 1'-0"

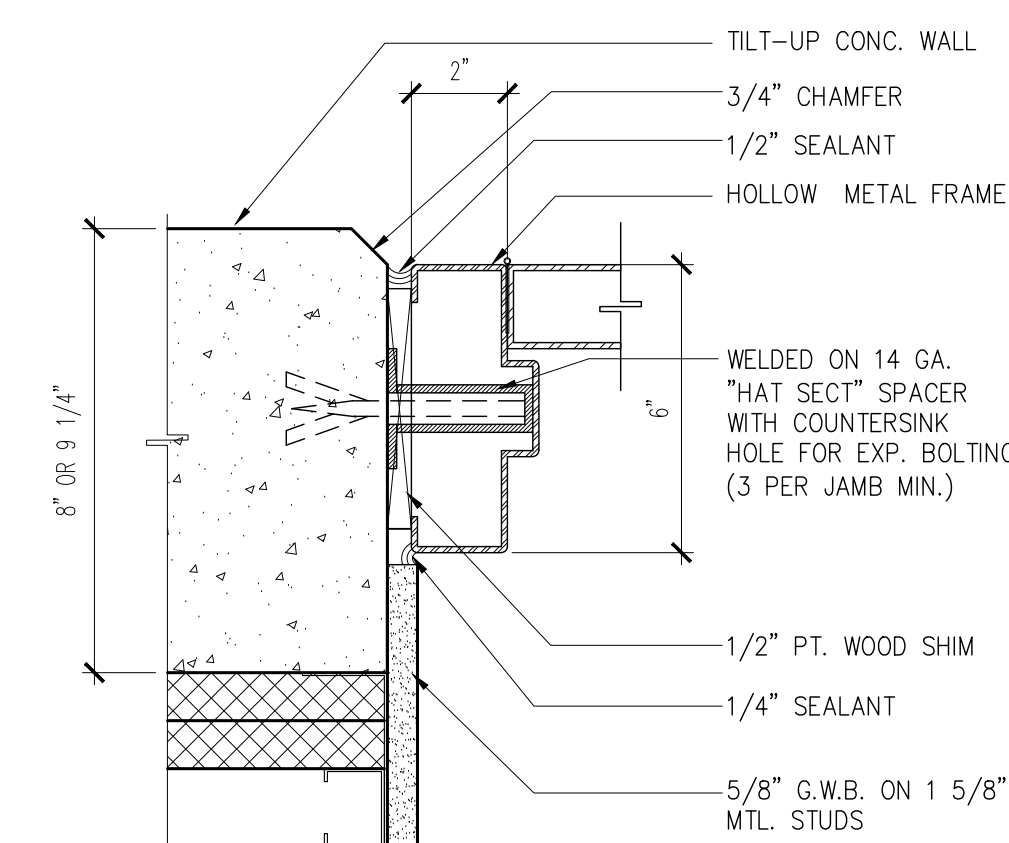

T-3 DOOR JAMB AND HEAD DETAIL
Scale: 3" = 1'-0"

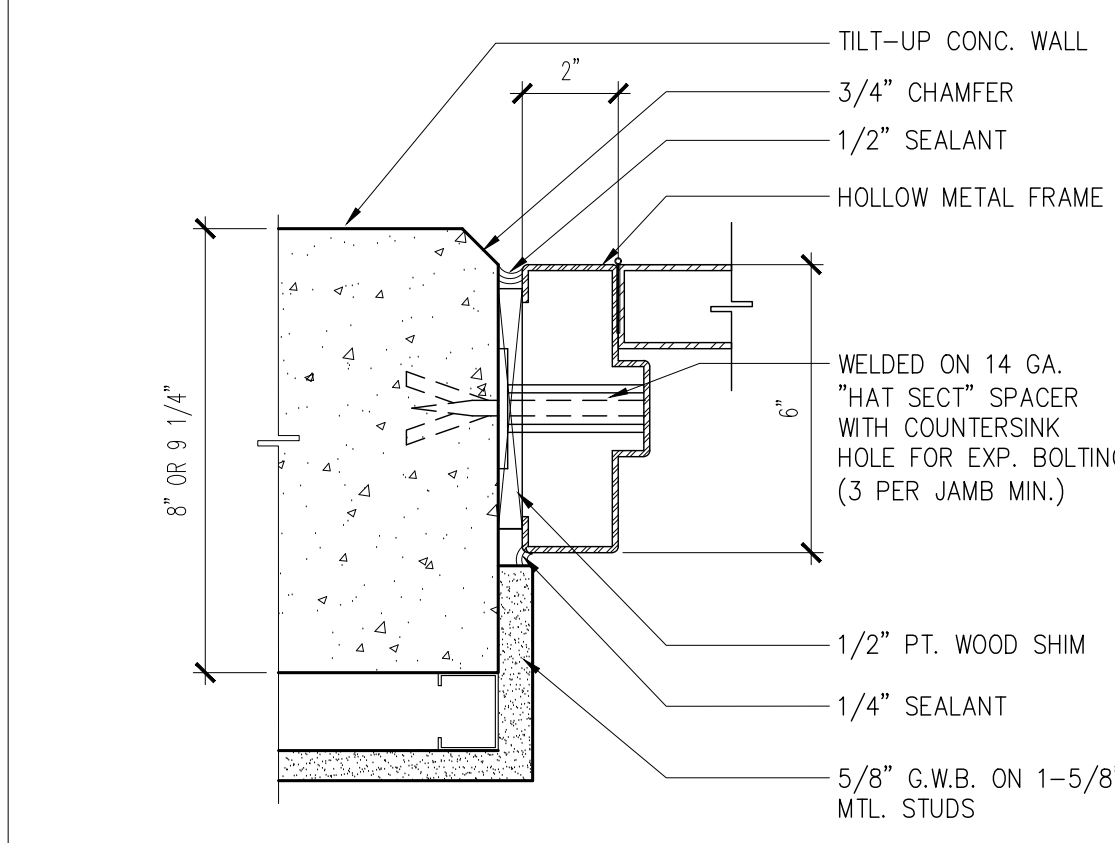

T-2 DOOR JAMB AND HEAD DETAIL
Scale: 3" = 1'-0"

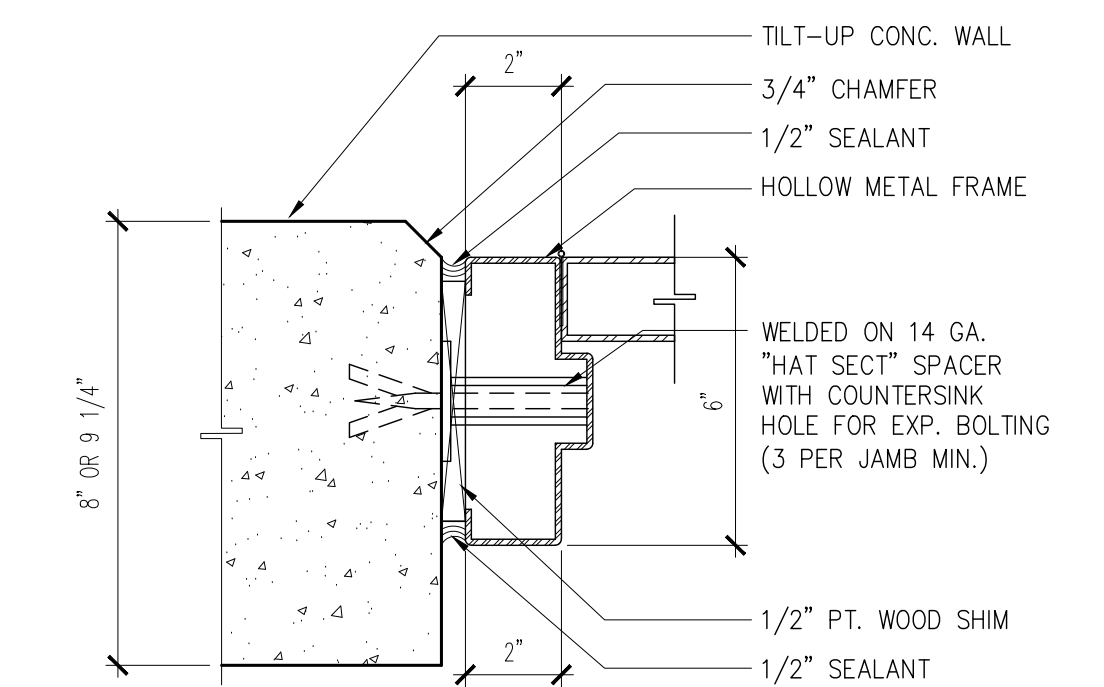

T-1 DOOR JAMB AND HEAD DETAIL
Scale: 3" = 1'-0"


CHECKED BY: LR	DRAWN BY: CV
-------------------	-----------------

CONSULTANT INFO:



NEW ELEMENTARY SCHOOL (K-5)
VENETIAN PARC WEST
SOUTHWEST 157th AVENUE and 174th STREET
MIAMI, FL. 33187
MDCPS PROJECT No. 01892600


KEY PLAN

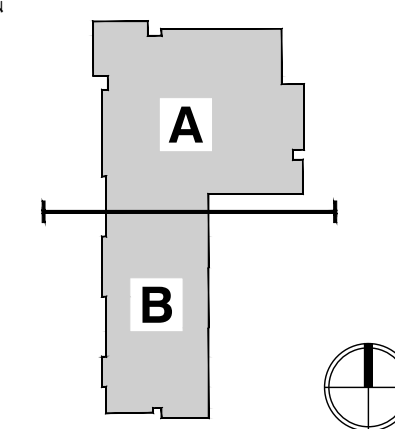

CONSULTANT INFO:



RODRIGUEZ ARCHITECTS INCORPORATED
2121 PONCE DE LEON BLVD. STE. 1010
CORAL GABLES, FL. 33134
TEL: (305) 448-3373
FAX: (305) 448-3374
A A C — 0 0 1 9 3 3

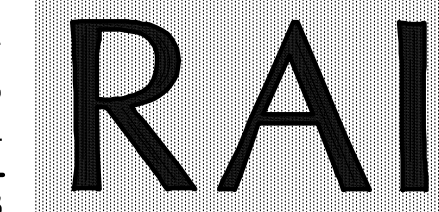


REVISIONS:


REVISIONS:	PROJECT NO.
	1906
	ISSUE DATE
	12/16/14
	SHEET
	A-320

DRAWING TITLE:


DOOR HEAD & JAMB DETAILS
SCALE AS NOTED
PROJECT NO. 1906
ISSUE DATE 12/16/14
SHEET A-320

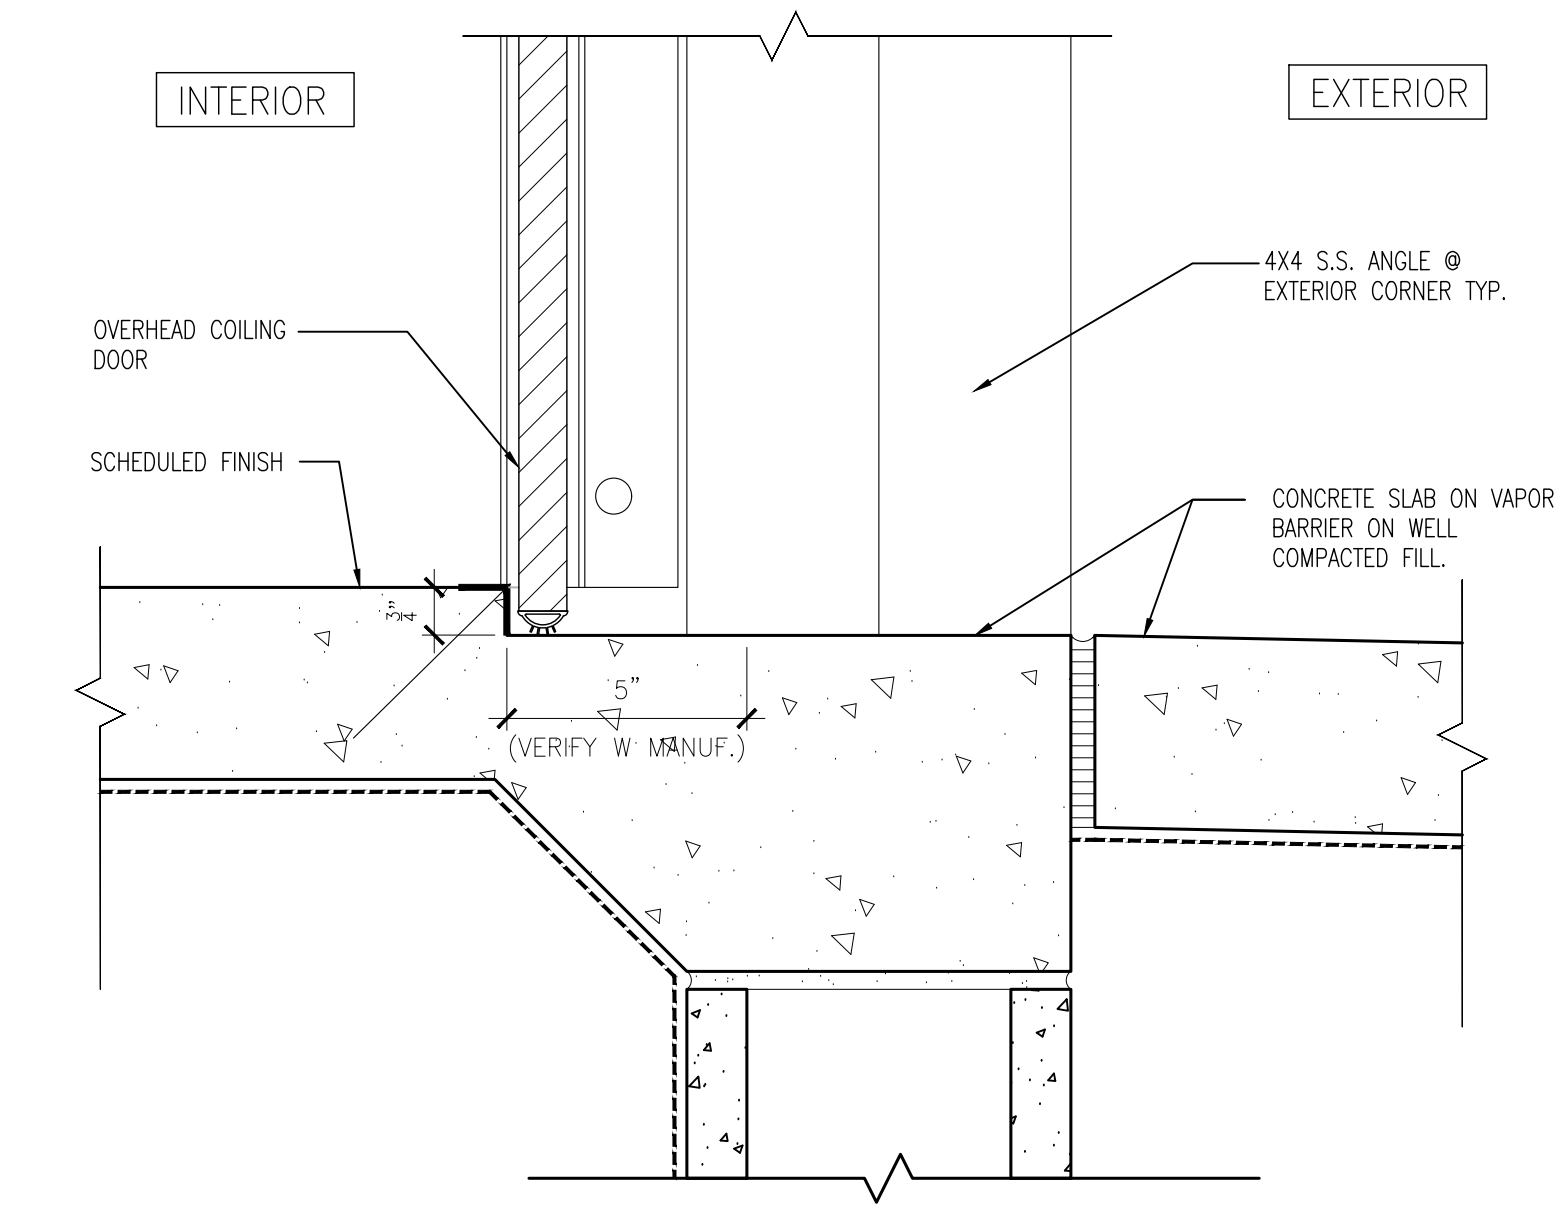


TH-9 THRESHOLD DETAIL
Scale: 3" = 1'-0"

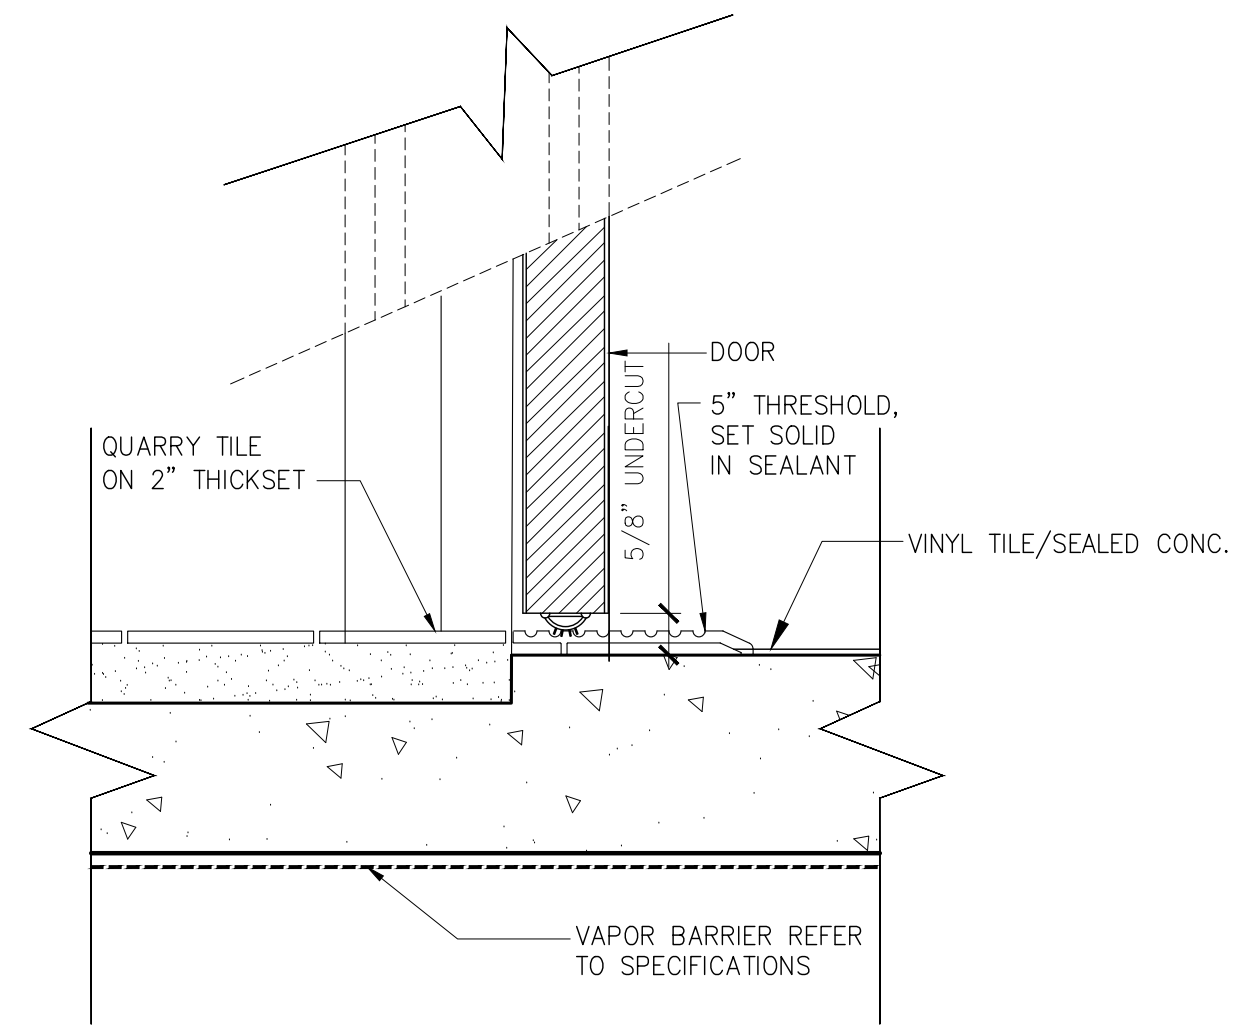


TH-8 THRESHOLD DETAIL
Scale: 3" = 1'-0"

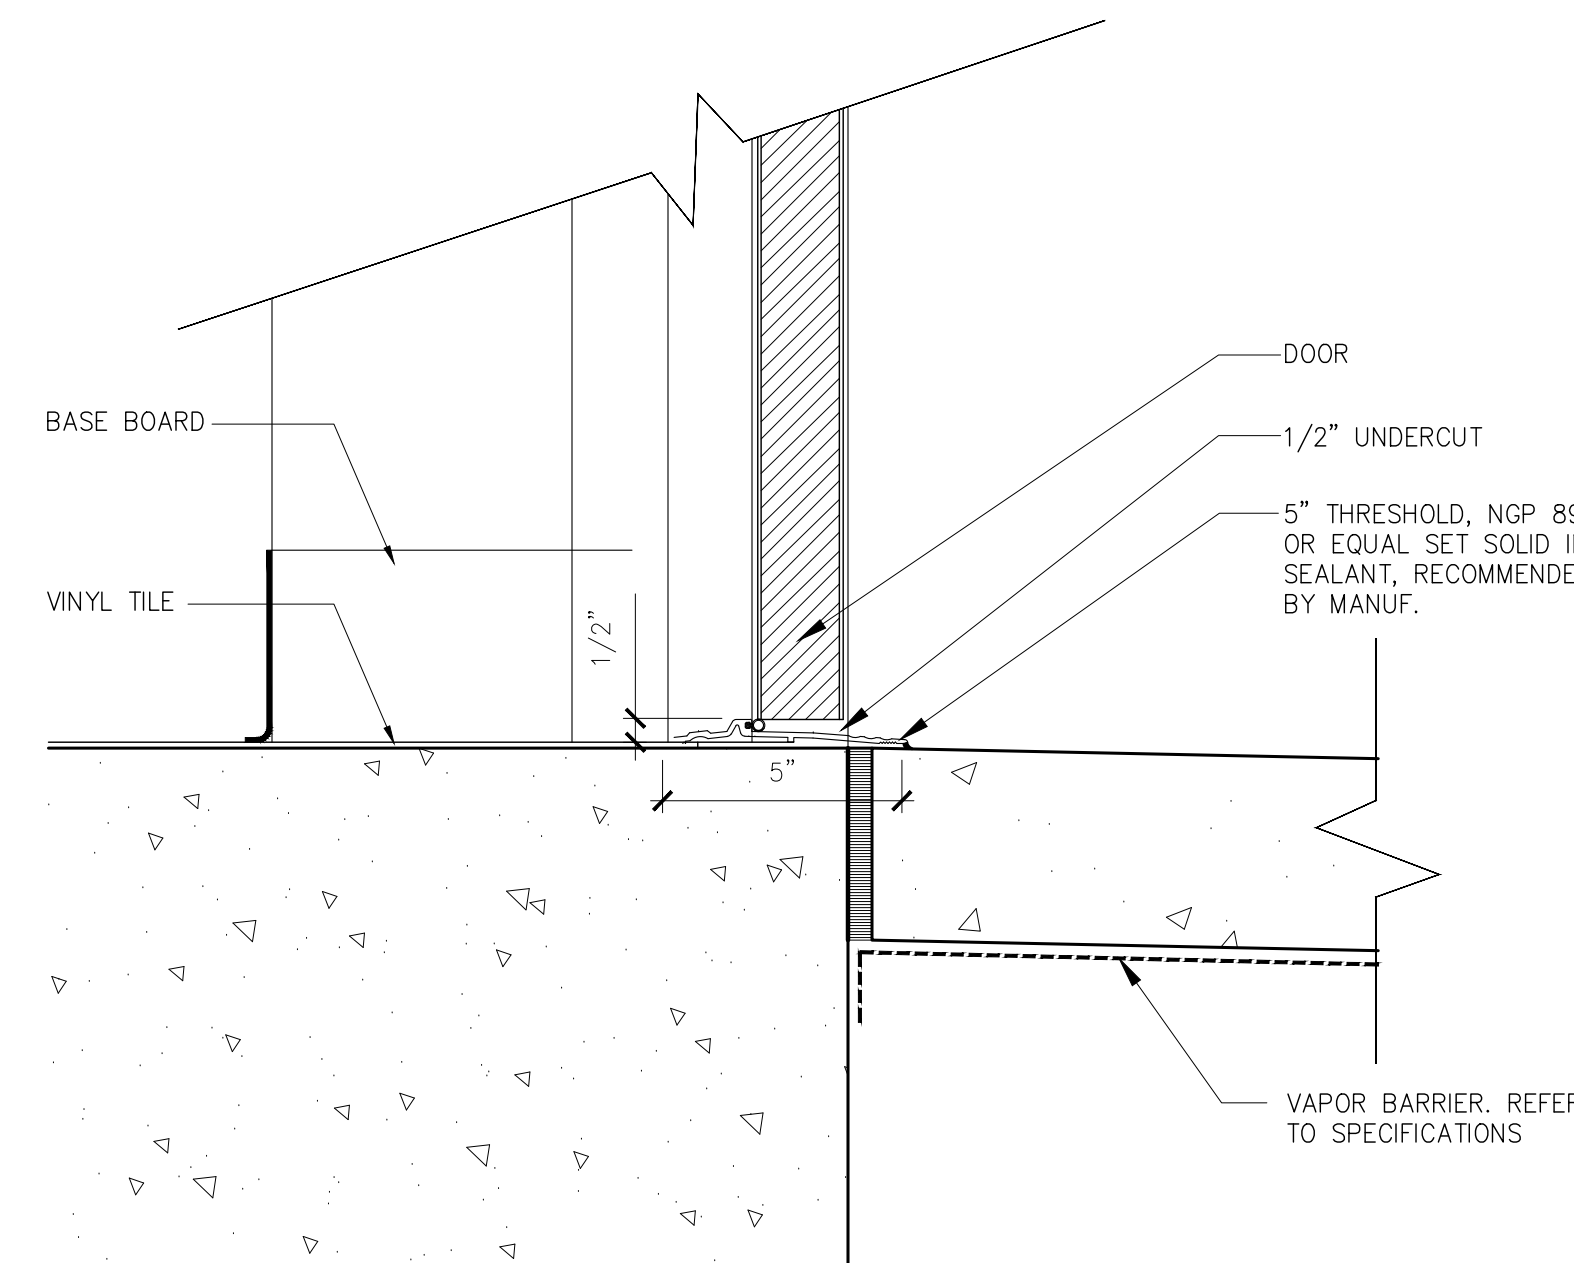


TH-7 THRESHOLD DETAIL
Scale: 3" = 1'-0"

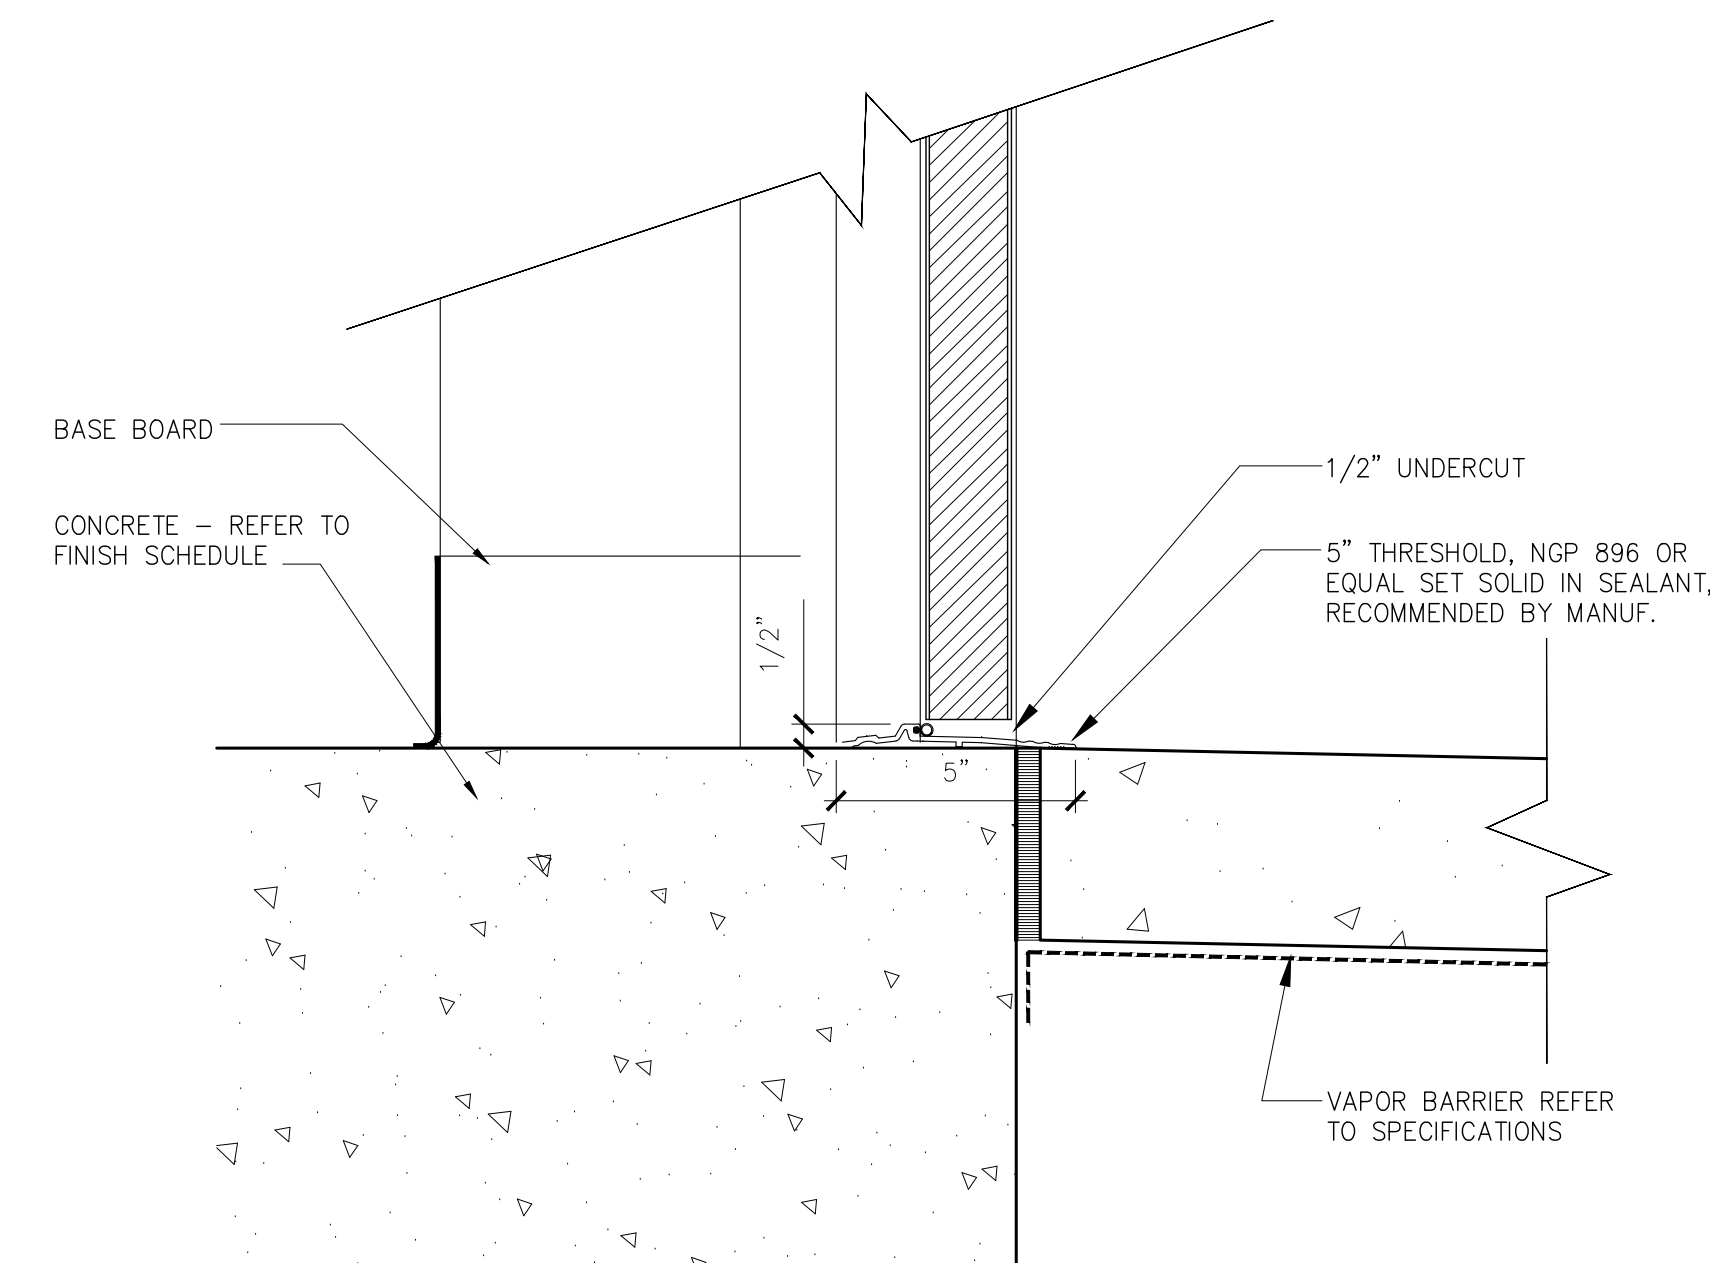


TH-6 THRESHOLD DETAIL
Scale: 3" = 1'-0"

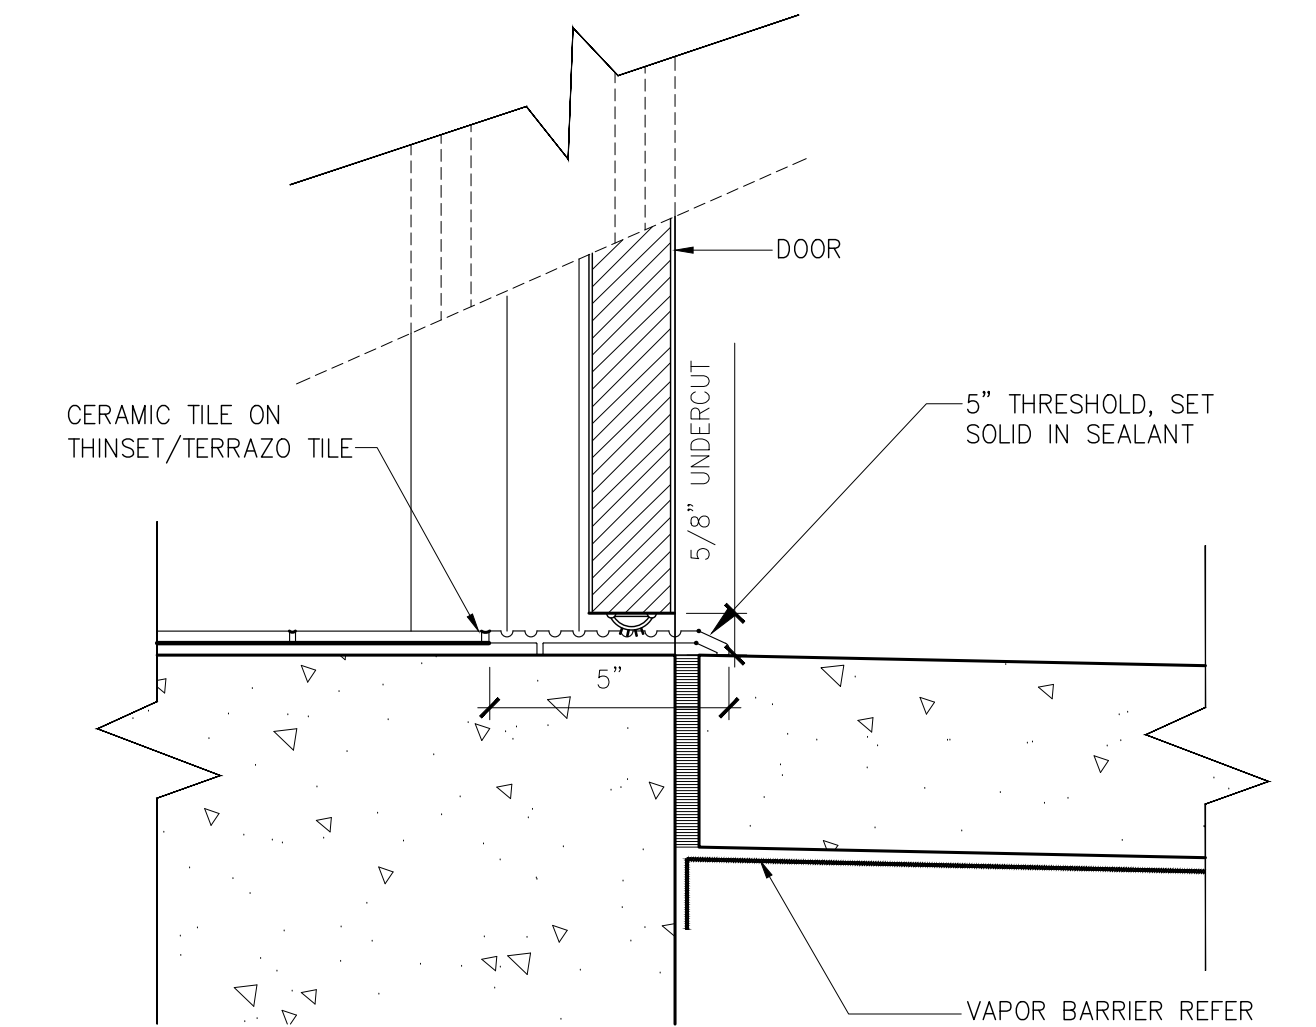


TH-5 THRESHOLD DETAIL
Scale: 3" = 1'-0"

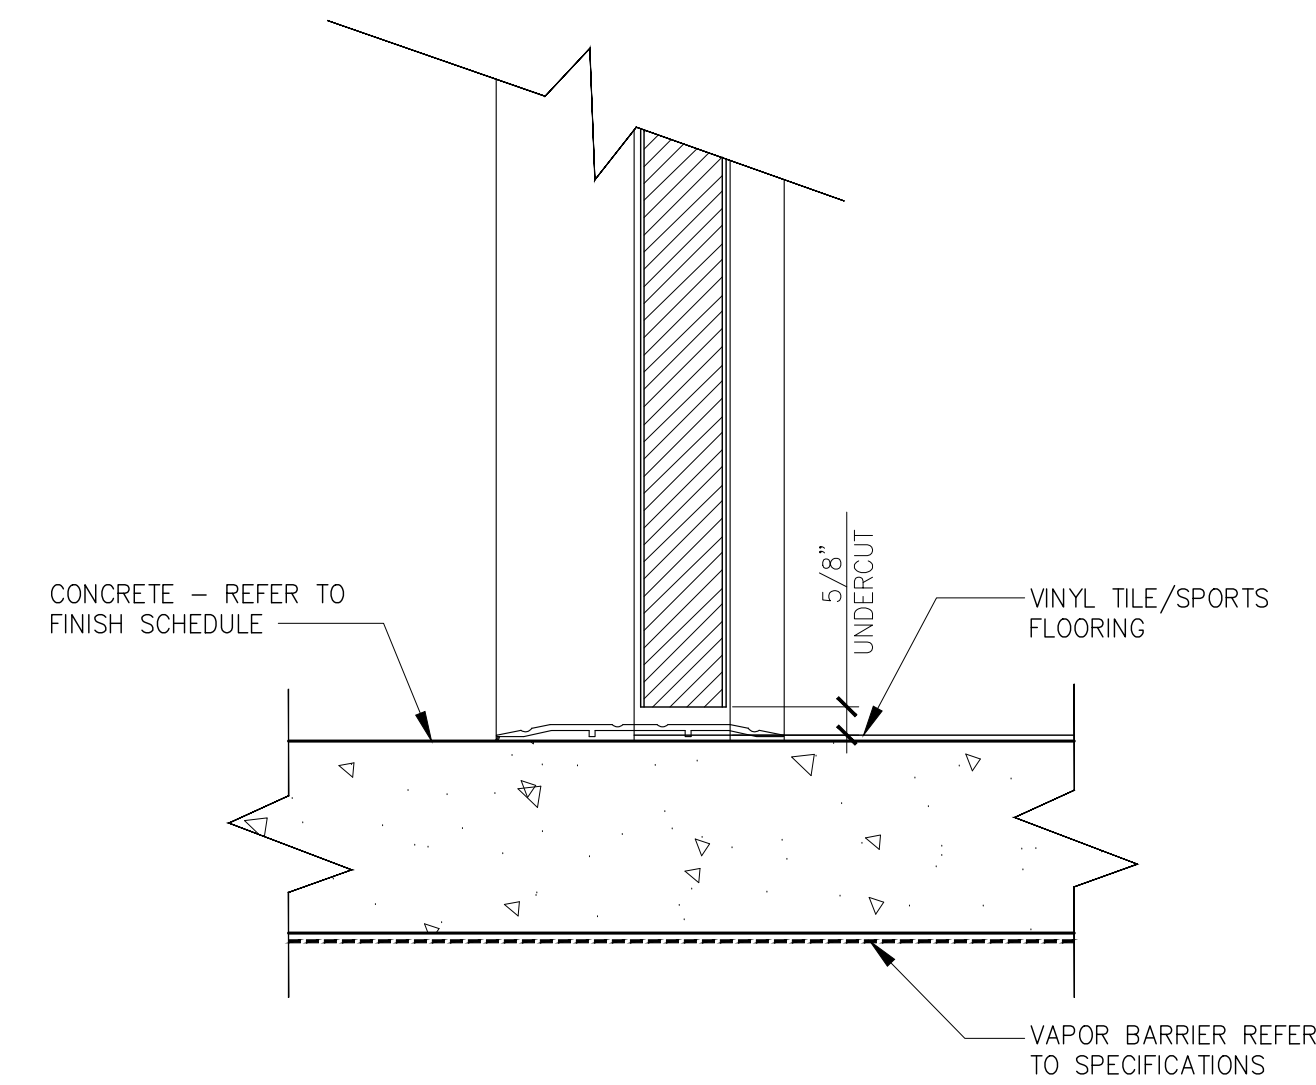


TH-4 THRESHOLD DETAIL
Scale: 3" = 1'-0"

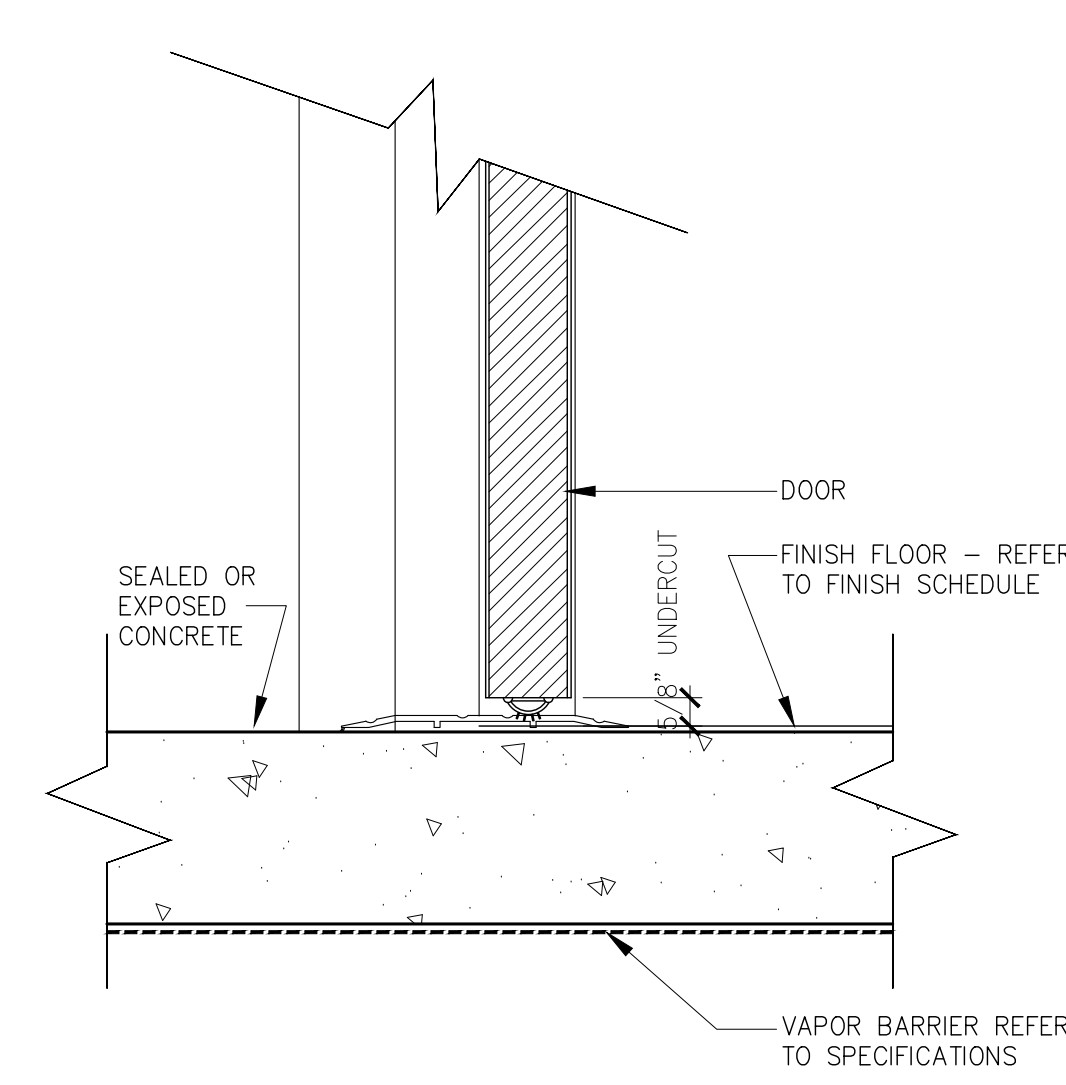

TH-3 THRESHOLD DETAIL
Scale: 3" = 1'-0"

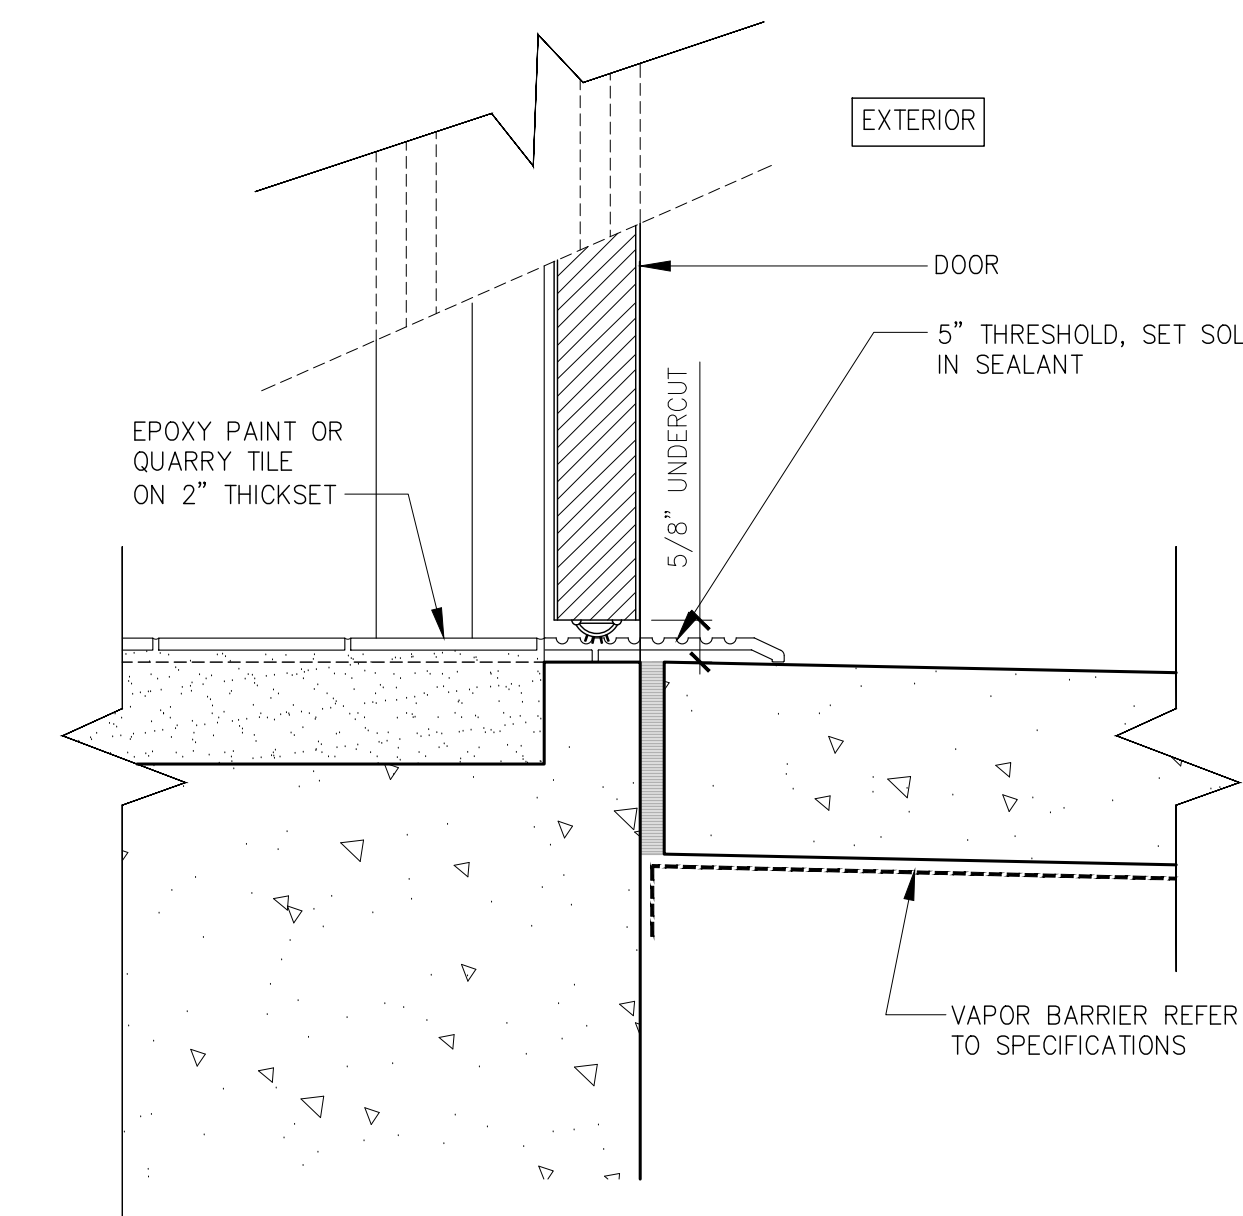

TH-2 THRESHOLD DETAIL
Scale: 3" = 1'-0"

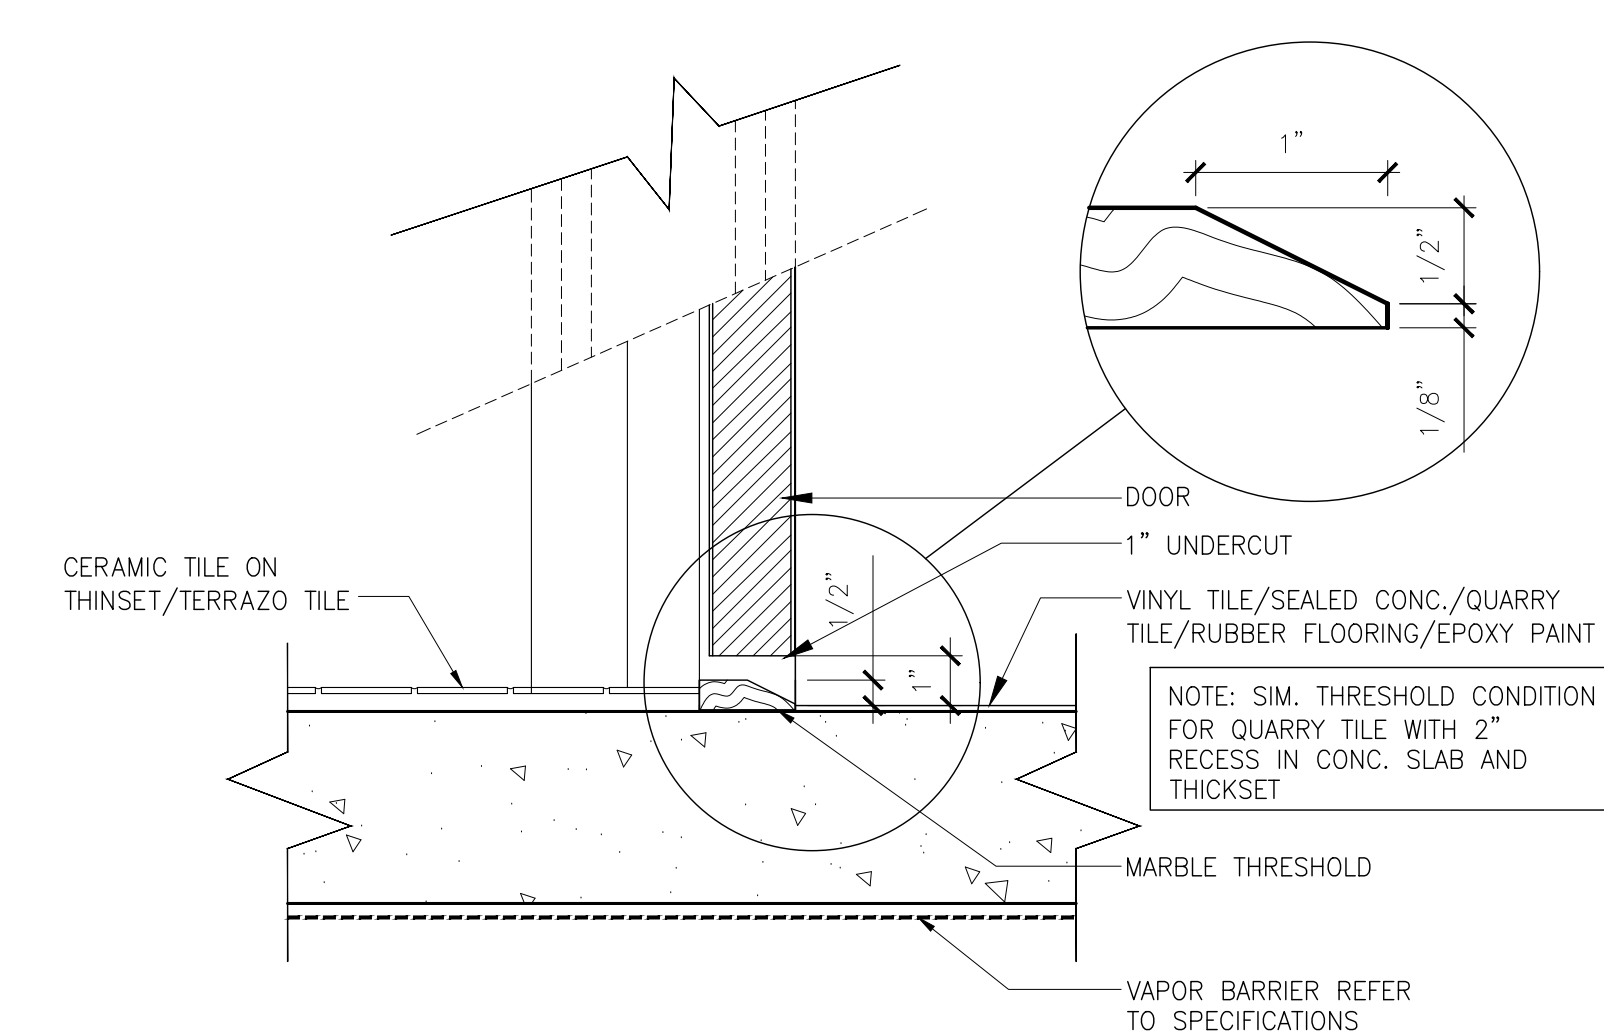

TH-1 THRESHOLD DETAIL
Scale: 3" = 1'-0"


CHECKED BY: LR.	DRAWN BY: C.V.
--------------------	-------------------

CONSULTANT INFO:



NEW ELEMENTARY SCHOOL (K-5)
VENETIAN PARC WEST
SOUTHWEST 157th AVENUE and 174th STREET
MIAMI, FL. 33187
MDCPS PROJECT No. 01892600

KEY PLAN

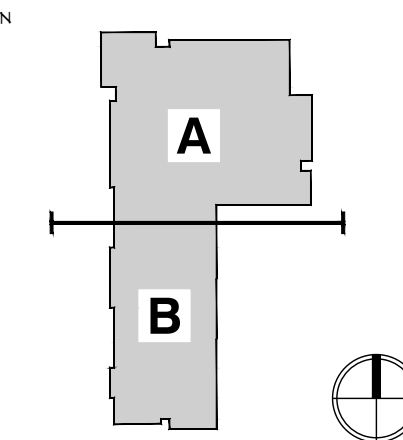

CONSULTANT INFO:

RODRIGUEZ ARCHITECTS
INCORPORATED
2121 PONCE DE LEON BLVD. STE. 1010
CORAL GABLES, FL. 33134
TEL: (305) 448-3373
FAX: (305) 448-3374
A A C — 0 0 1 9 3 3

**RODRIGUEZ ARCHITECTS
INCORPORATED**
2121 PONCE DE LEON BLVD. STE. 1010
CORAL GABLES, FL. 33134
TEL: (305) 448-3373
FAX: (305) 448-3374
A A C — 0 0 1 9 3 3




REVISIONS:


REVISIONS:	PROJECT NO.
	1906
	SHEET:
	A-821

DRAWING TITLE:


DOOR THRESHOLD DETAILS	
SCALE AS NOTED	
ISSUE DATE	PROJECT NO.
12/16/14	1906
SHEET:	
A-821	

 


11 **LOUVER - HEAD DETAIL**
Scale: 3" = 1'-0"

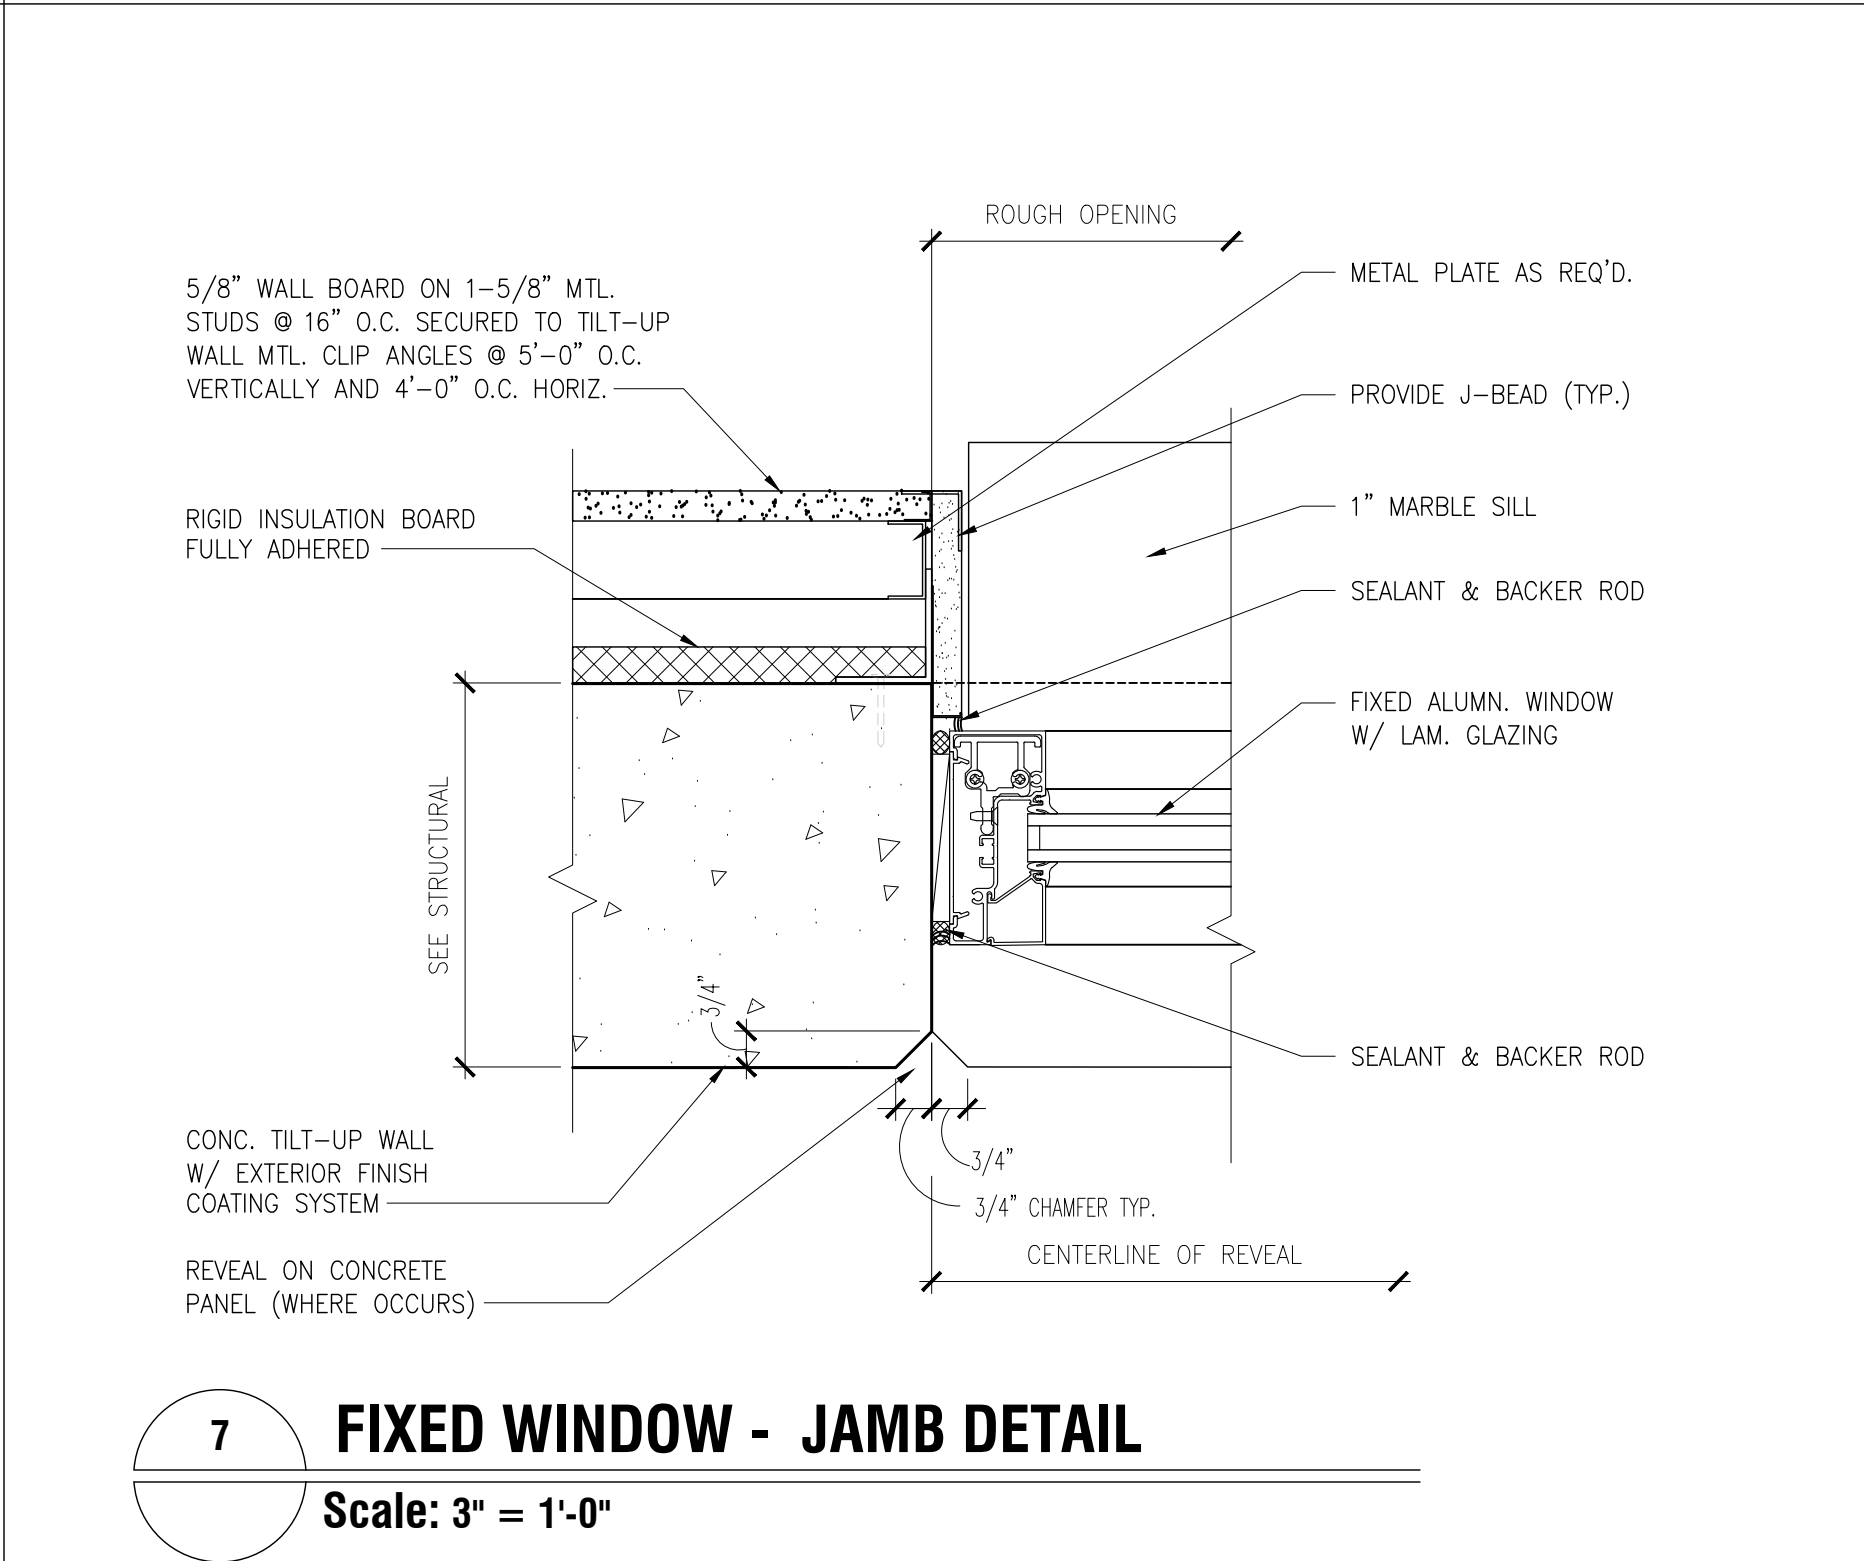


10 **LOUVER - SILL DETAIL**
Scale: 3" = 1'-0"

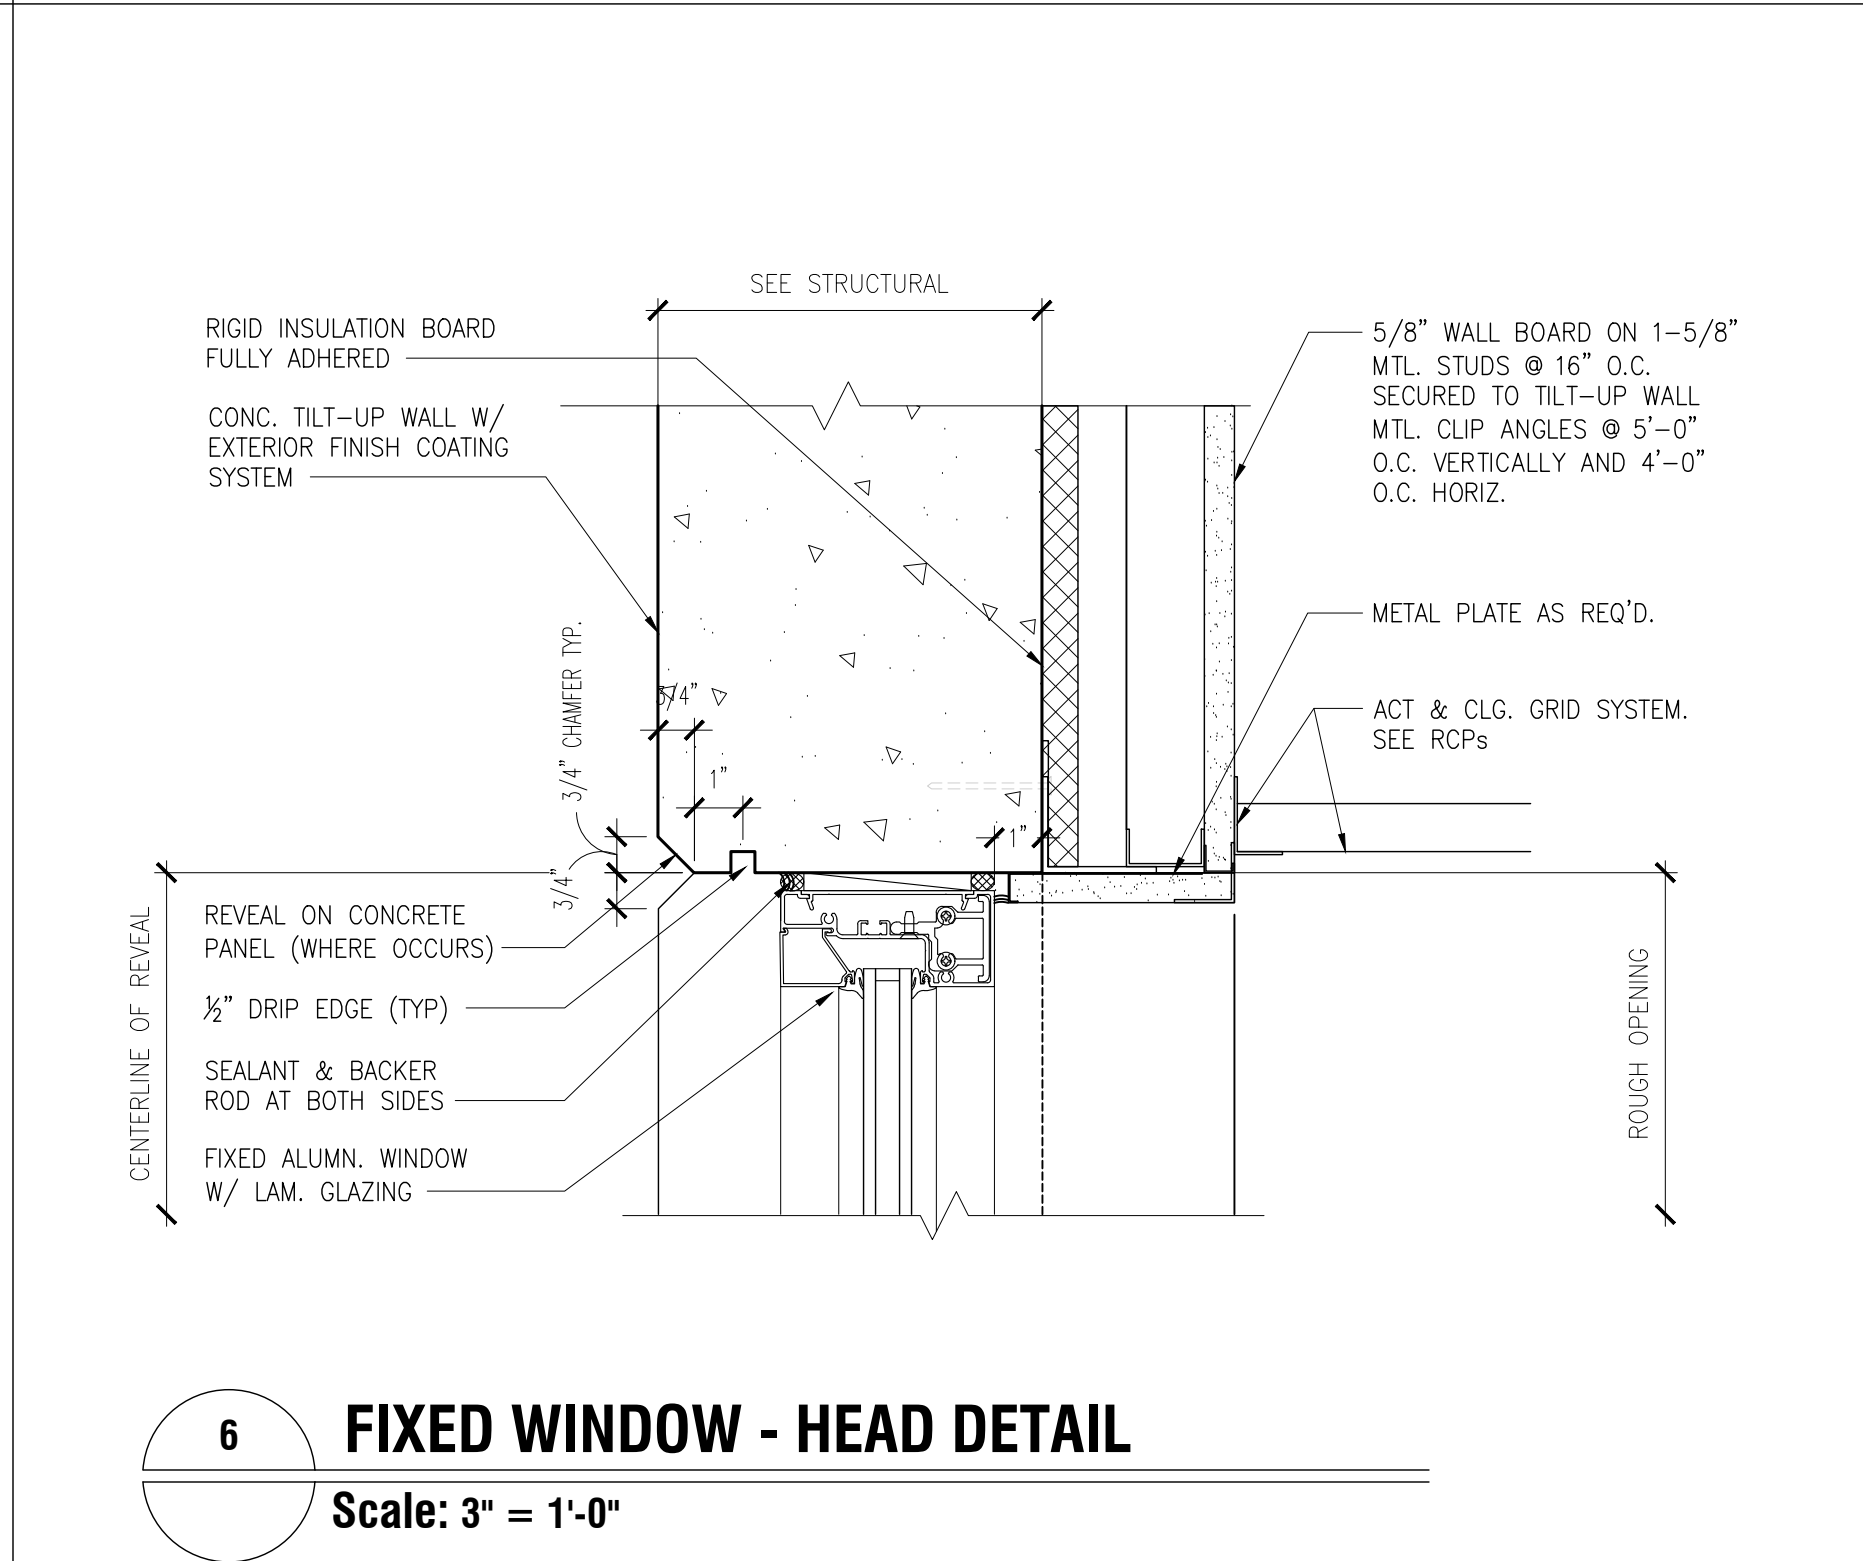


9 **LOUVER - JAMB DETAIL**
Scale: 3" = 1'-0"

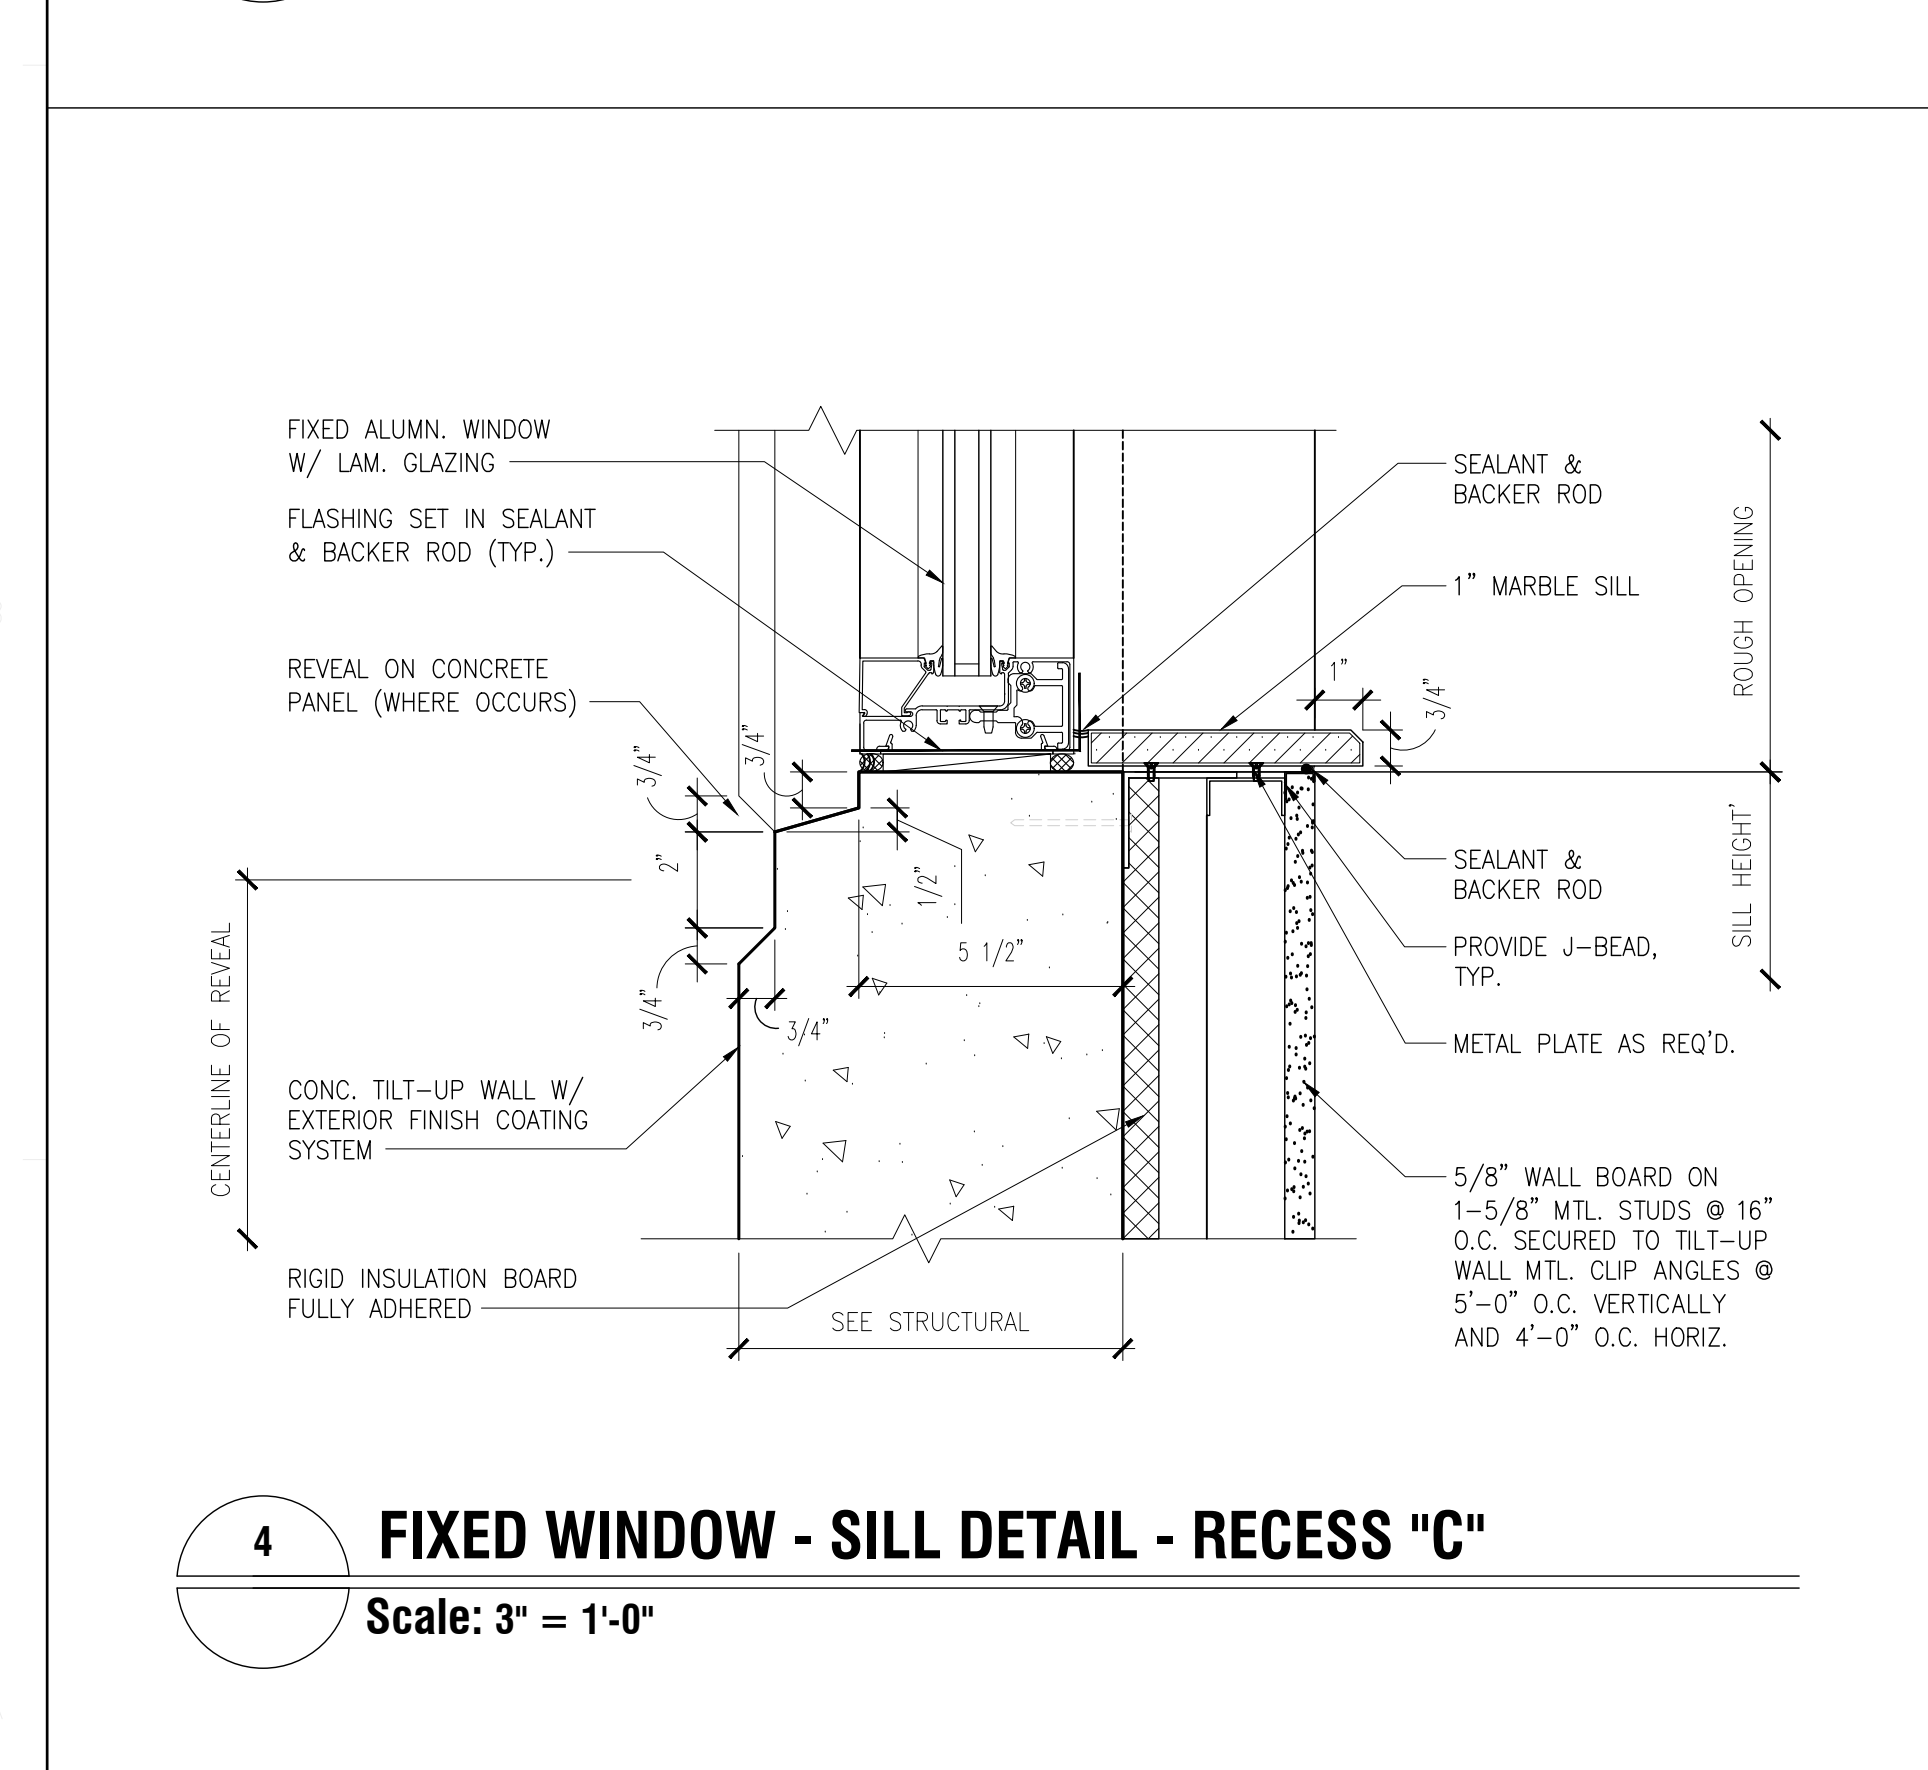


8 **CASEMENT WINDOW - JAMB DETAIL**
Scale: 3" = 1'-0"

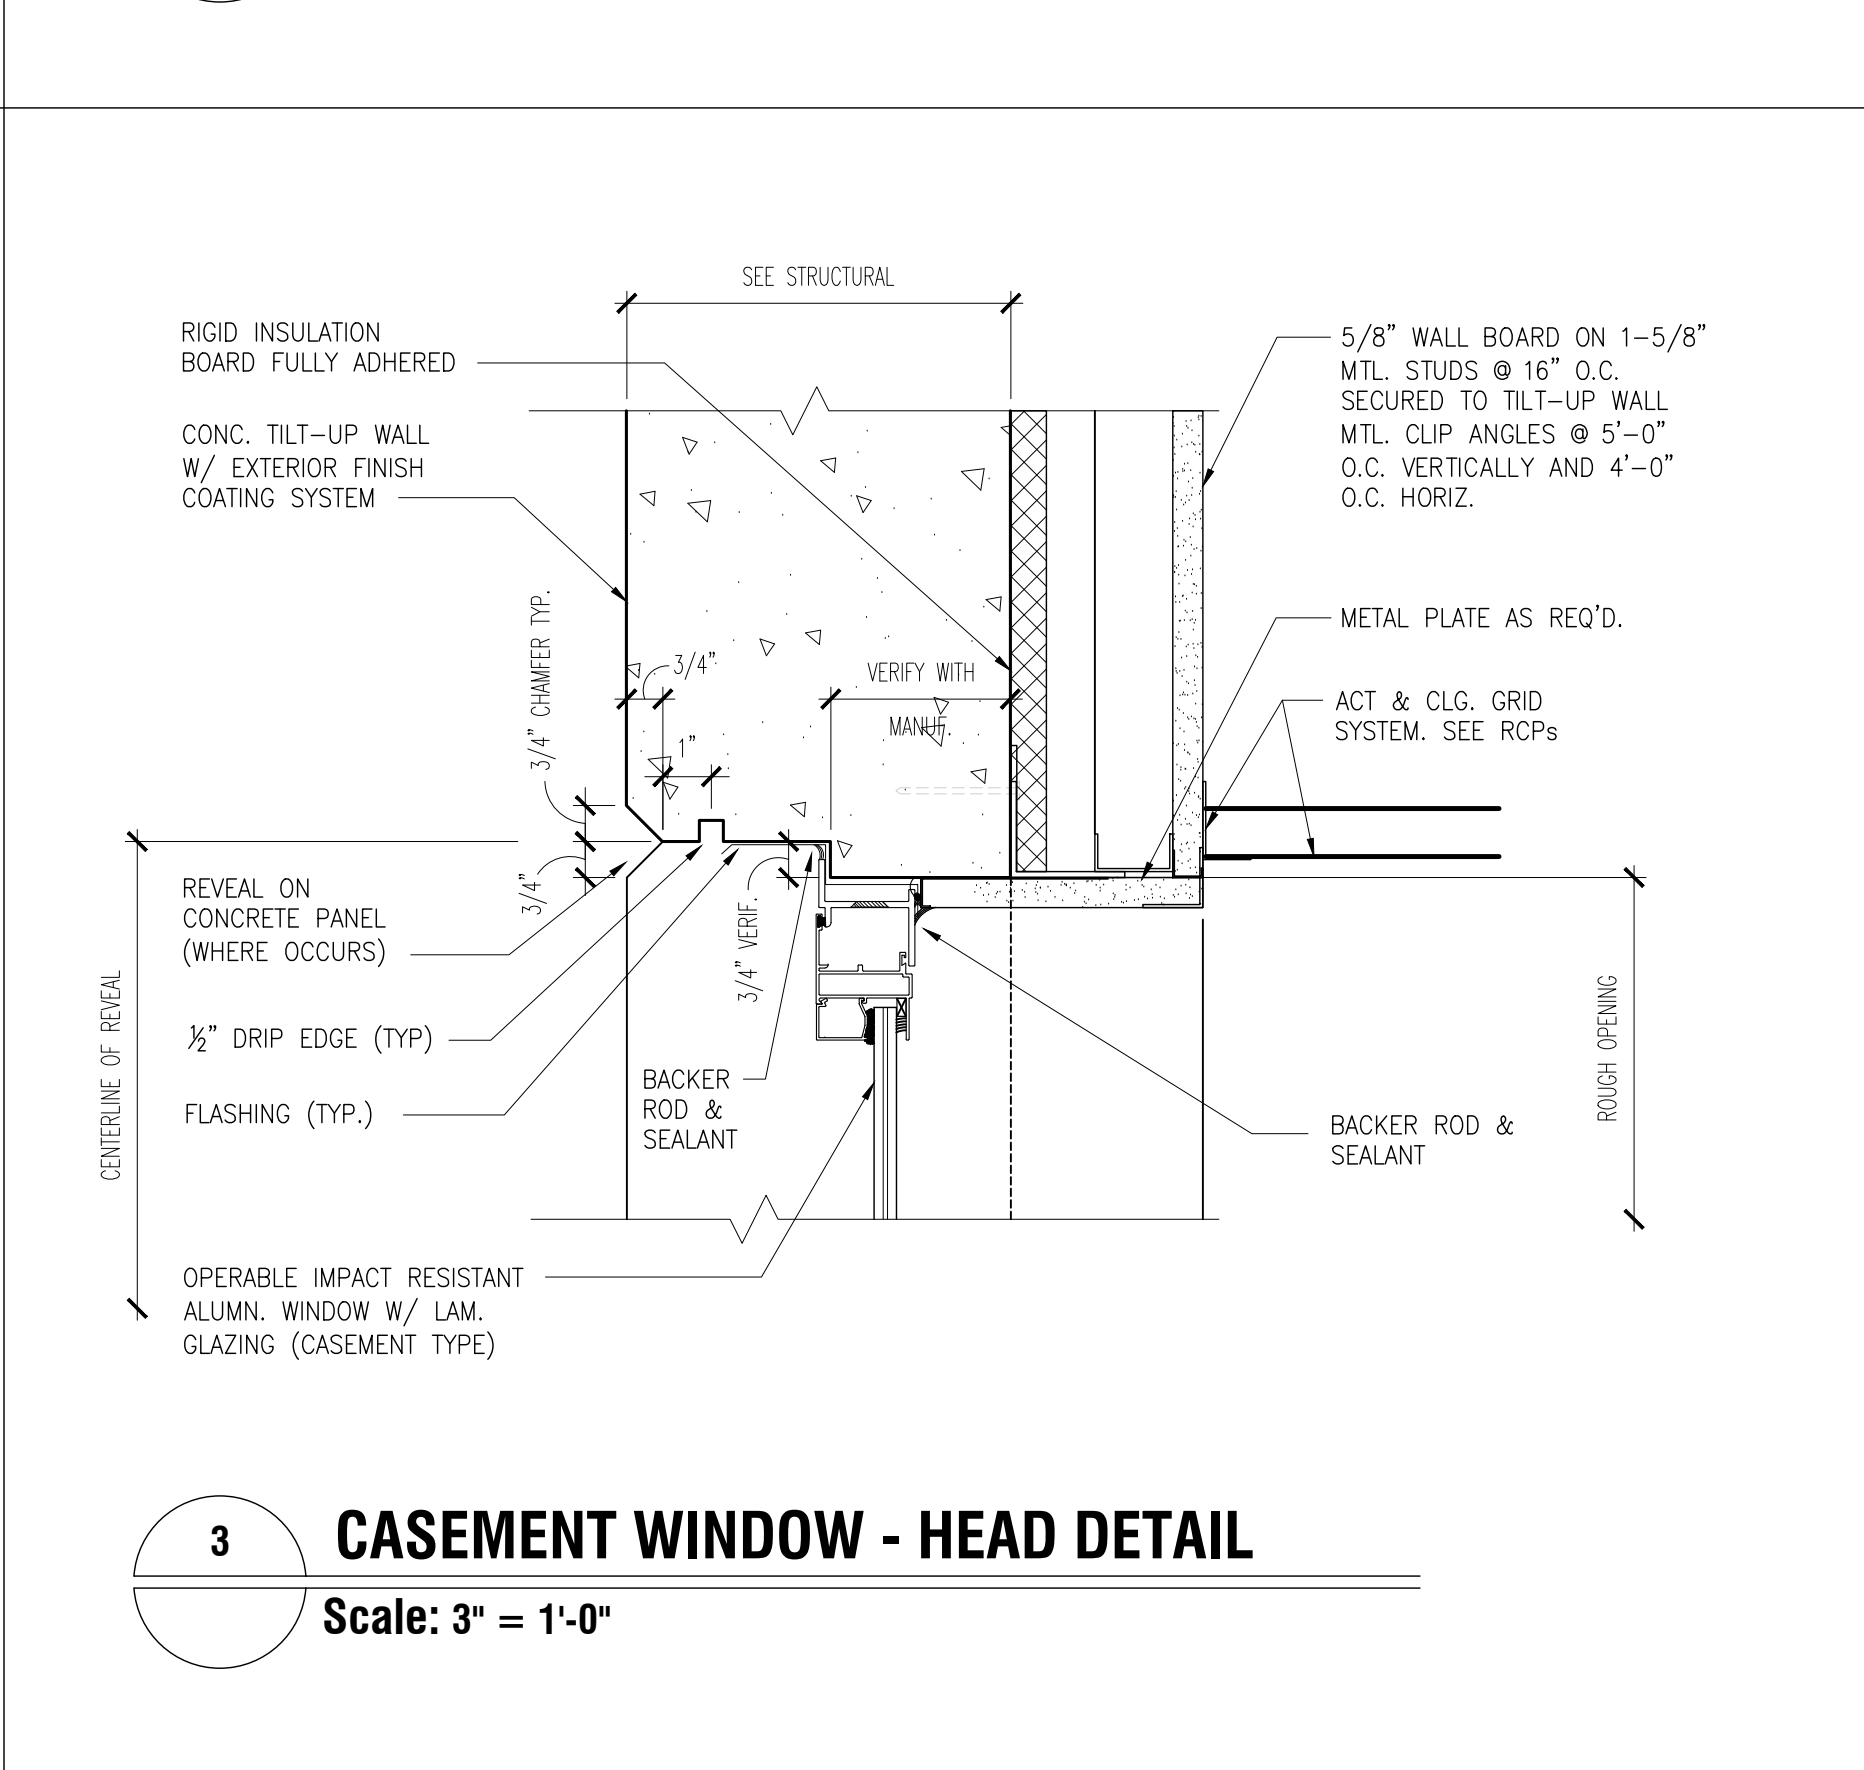


7 **FIXED WINDOW - JAMB DETAIL**
Scale: 3" = 1'-0"

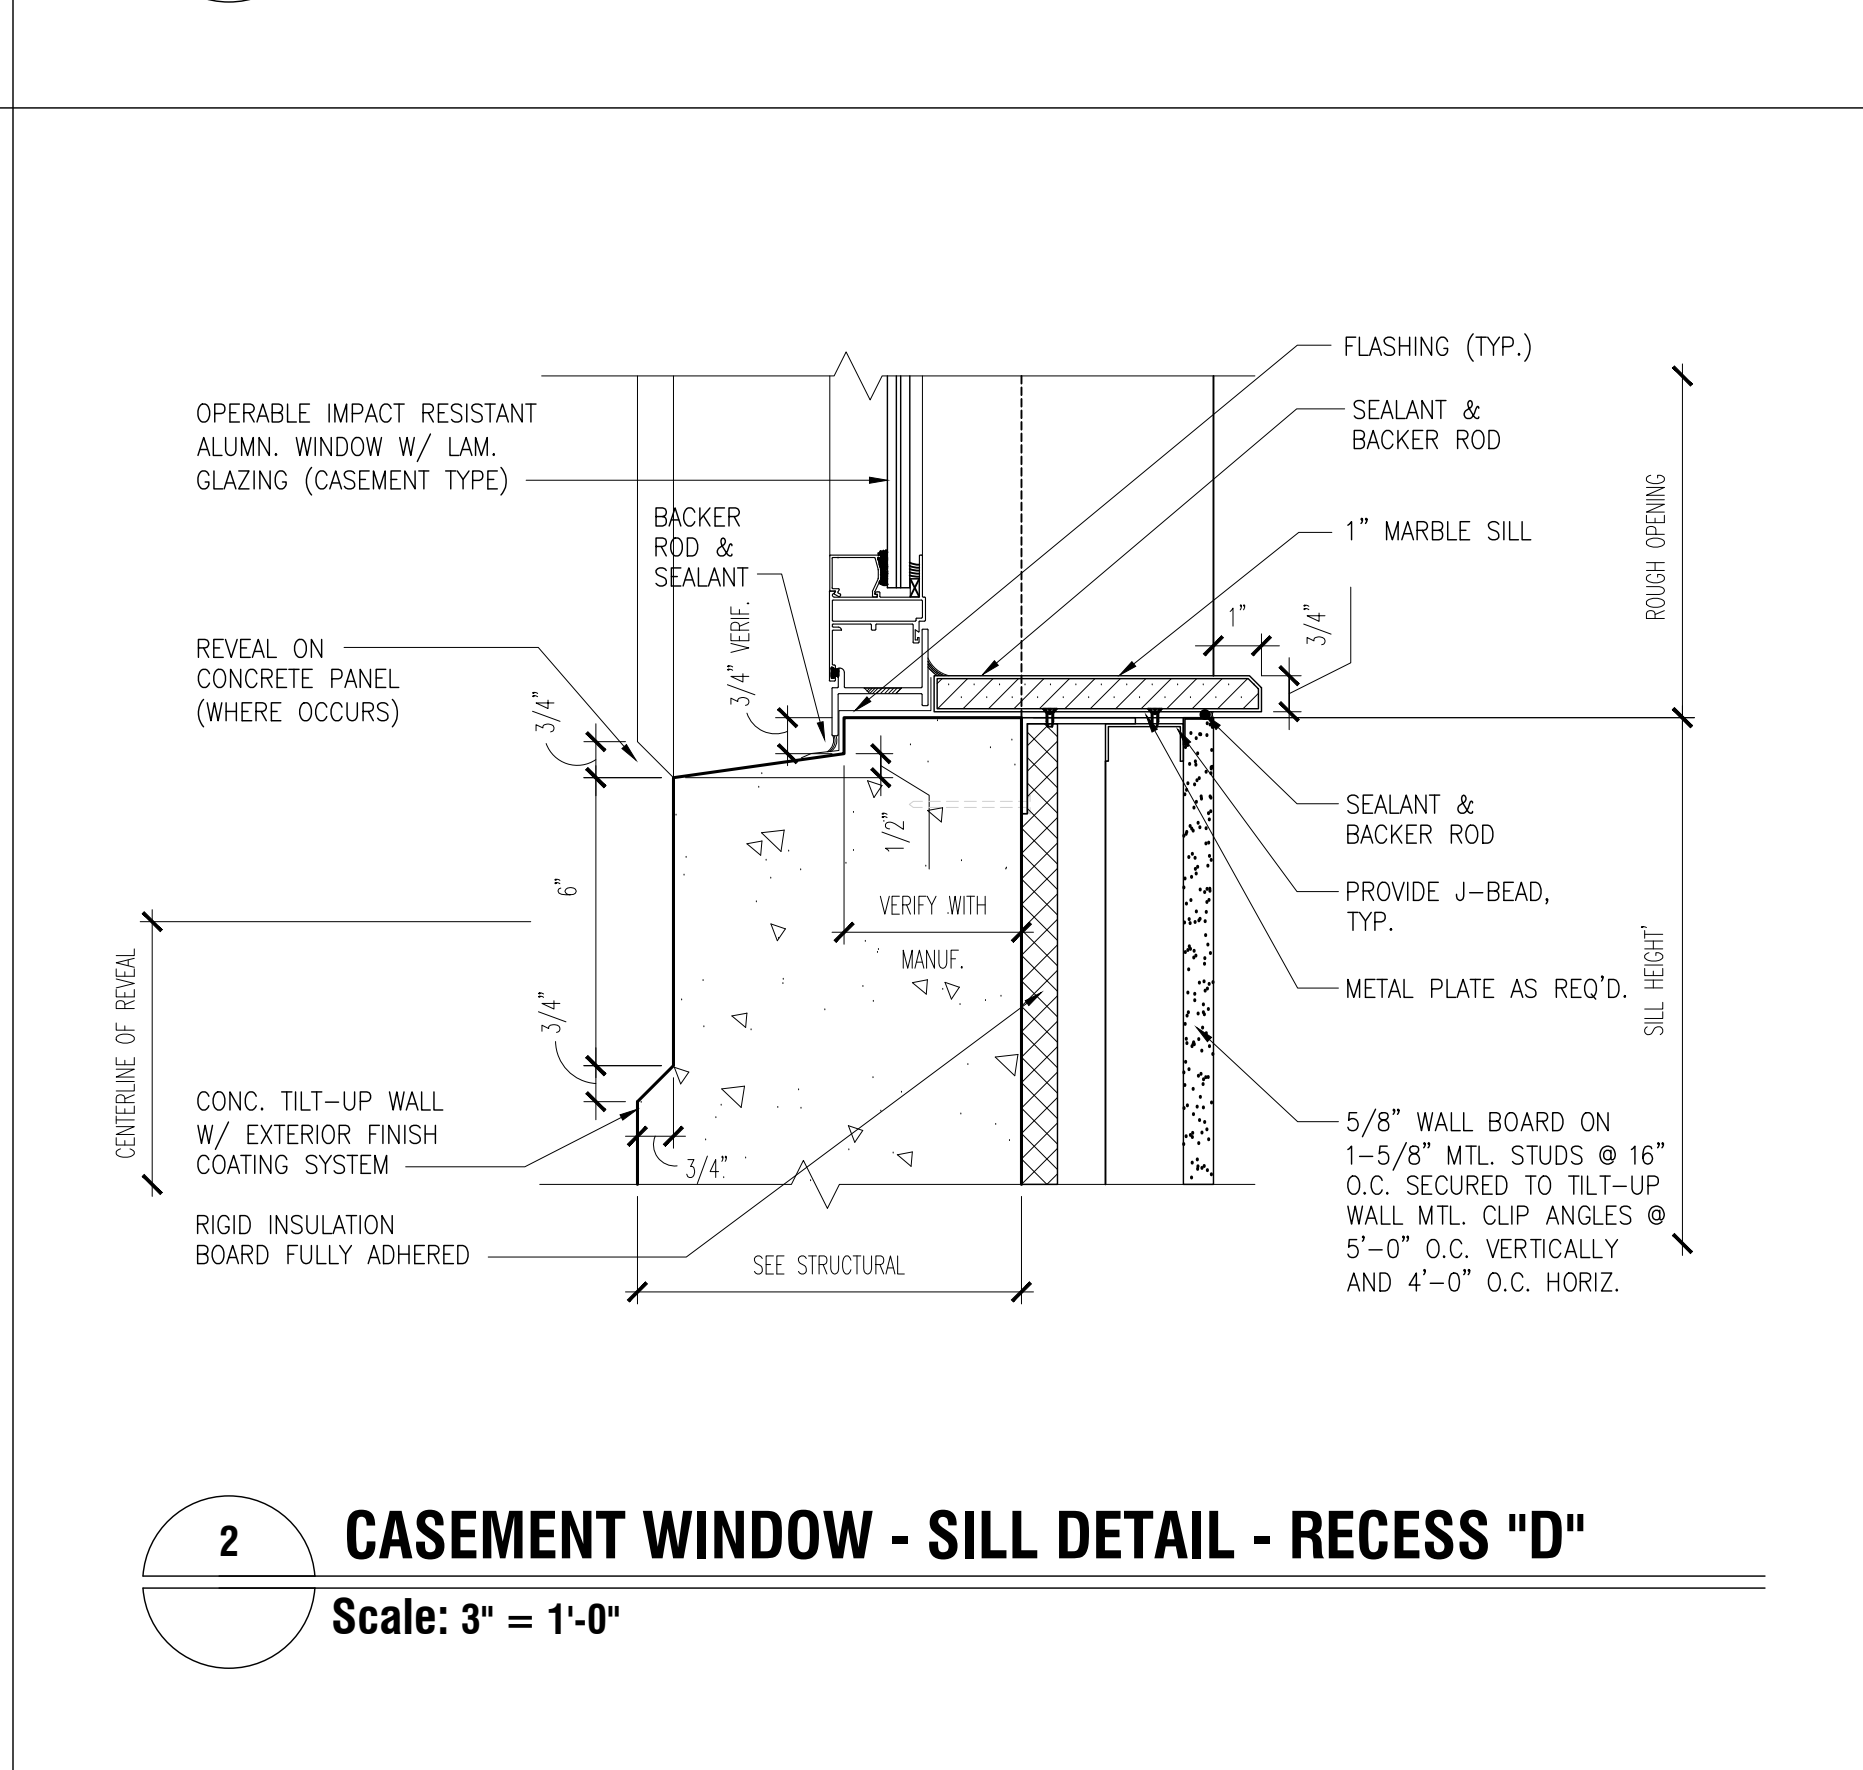

6 **FIXED WINDOW - HEAD DETAIL**
Scale: 3" = 1'-0"

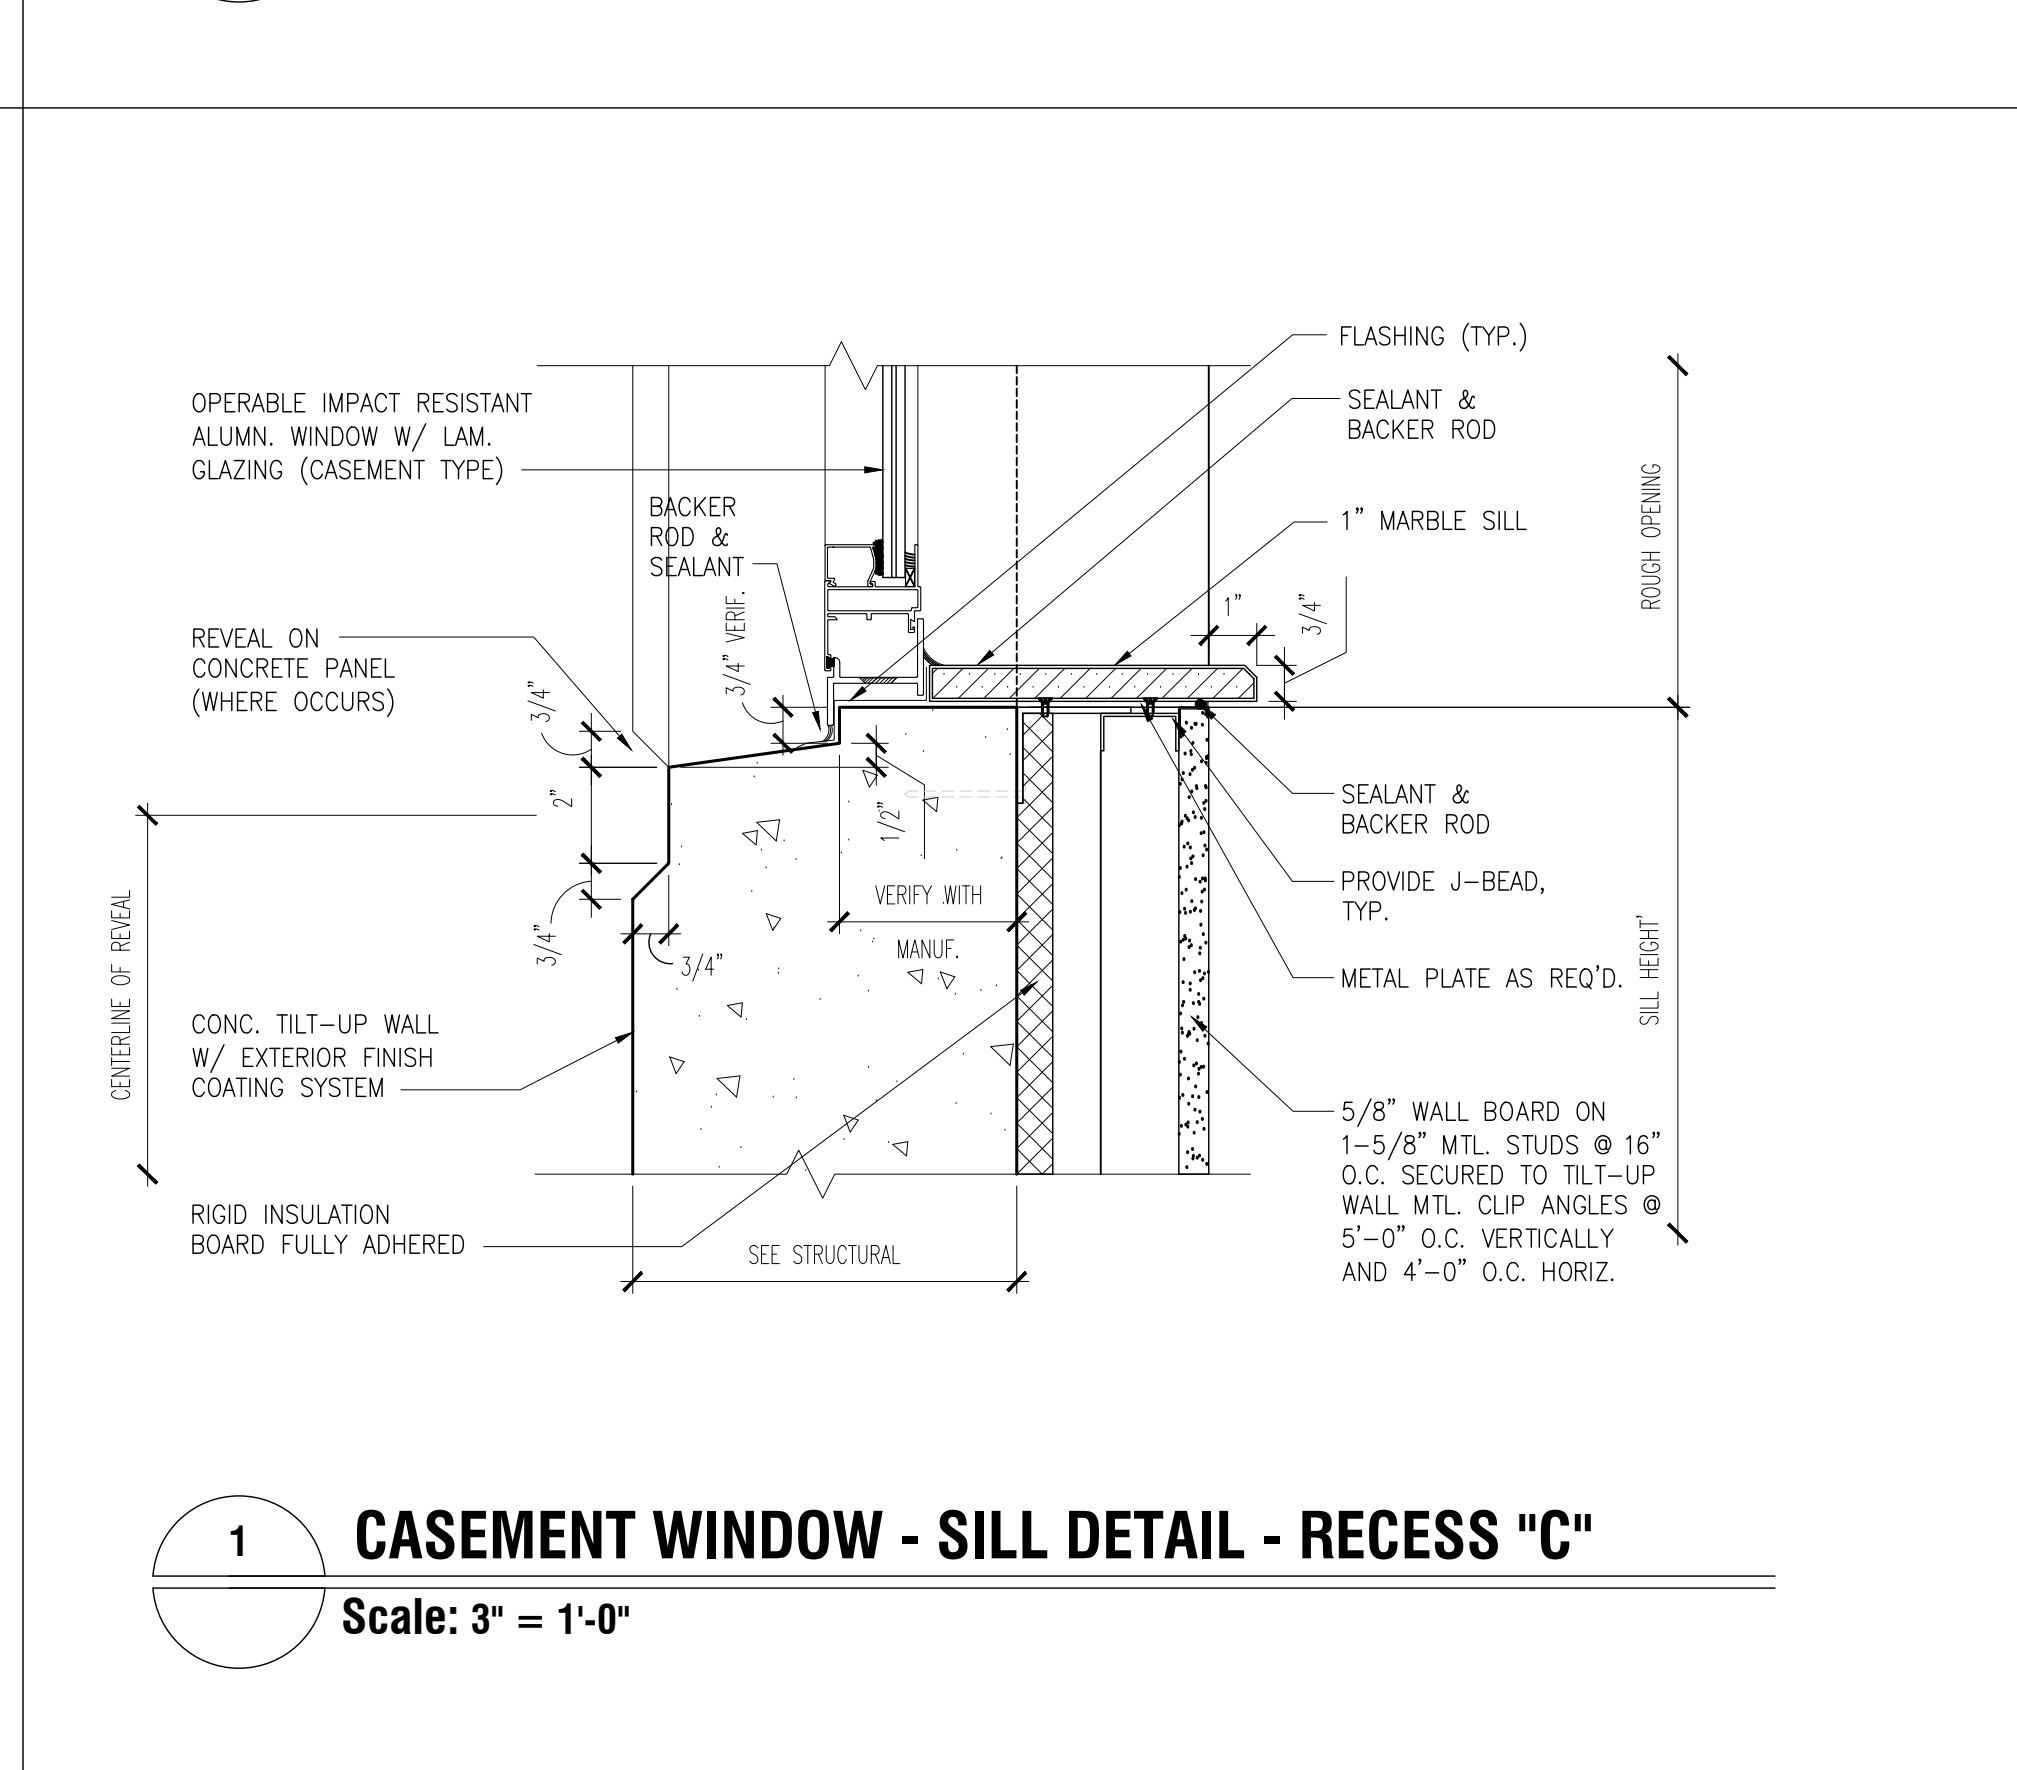


5 **FIXED WINDOW - SILL DETAIL - RECESS "D"**
Scale: 3" = 1'-0"

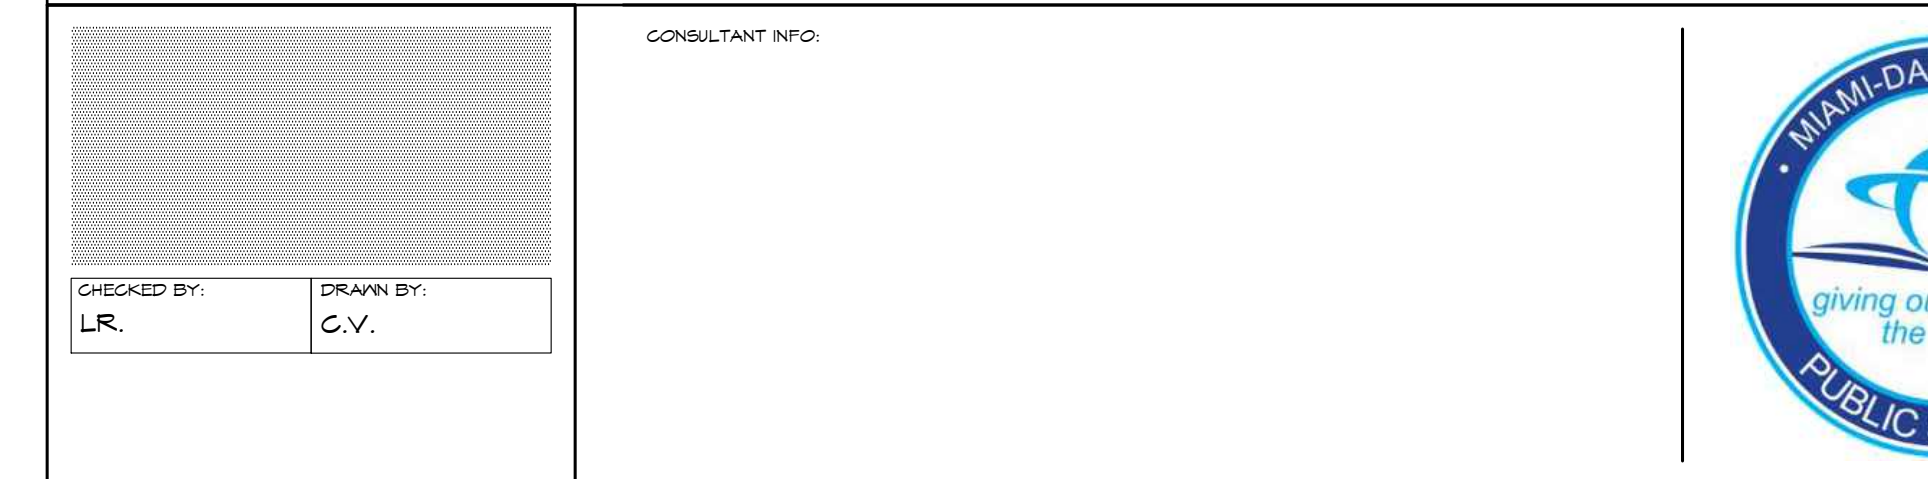


4 **FIXED WINDOW - SILL DETAIL - RECESS "C"**
Scale: 3" = 1'-0"



3 **CASEMENT WINDOW - HEAD DETAIL**
Scale: 3" = 1'-0"

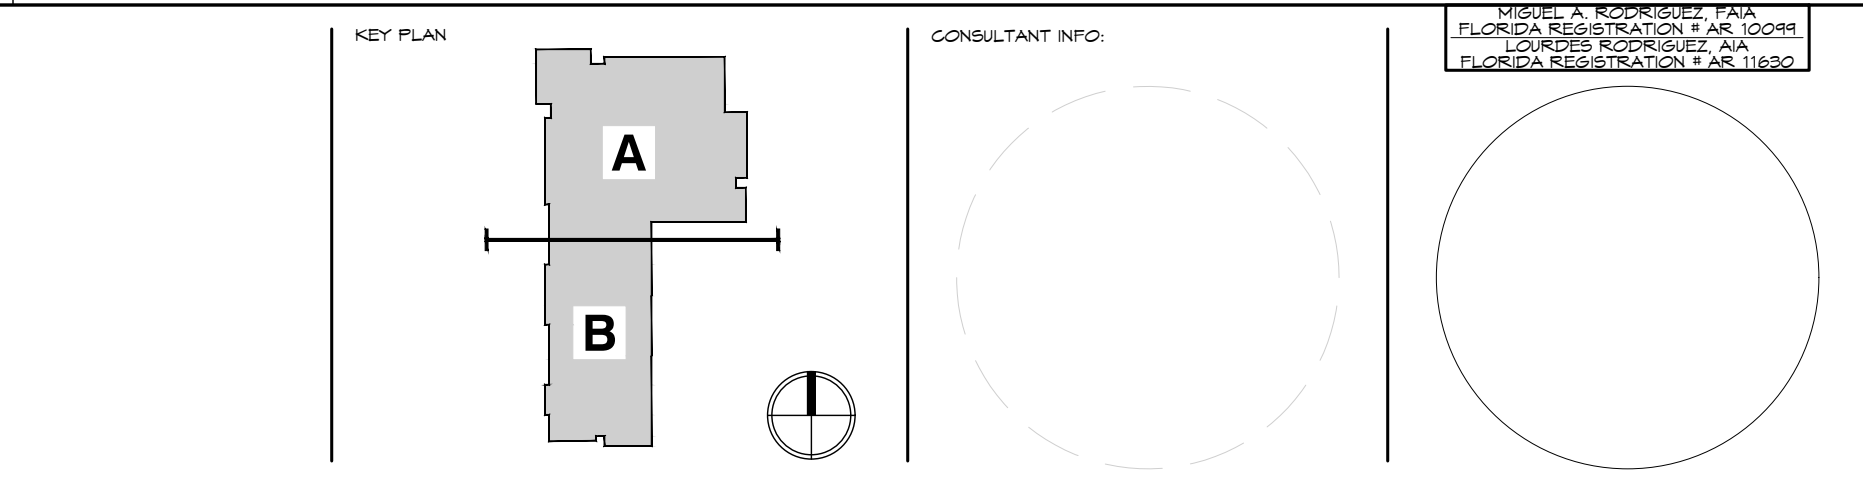

2 **CASEMENT WINDOW - SILL DETAIL - RECESS "D"**
Scale: 3" = 1'-0"

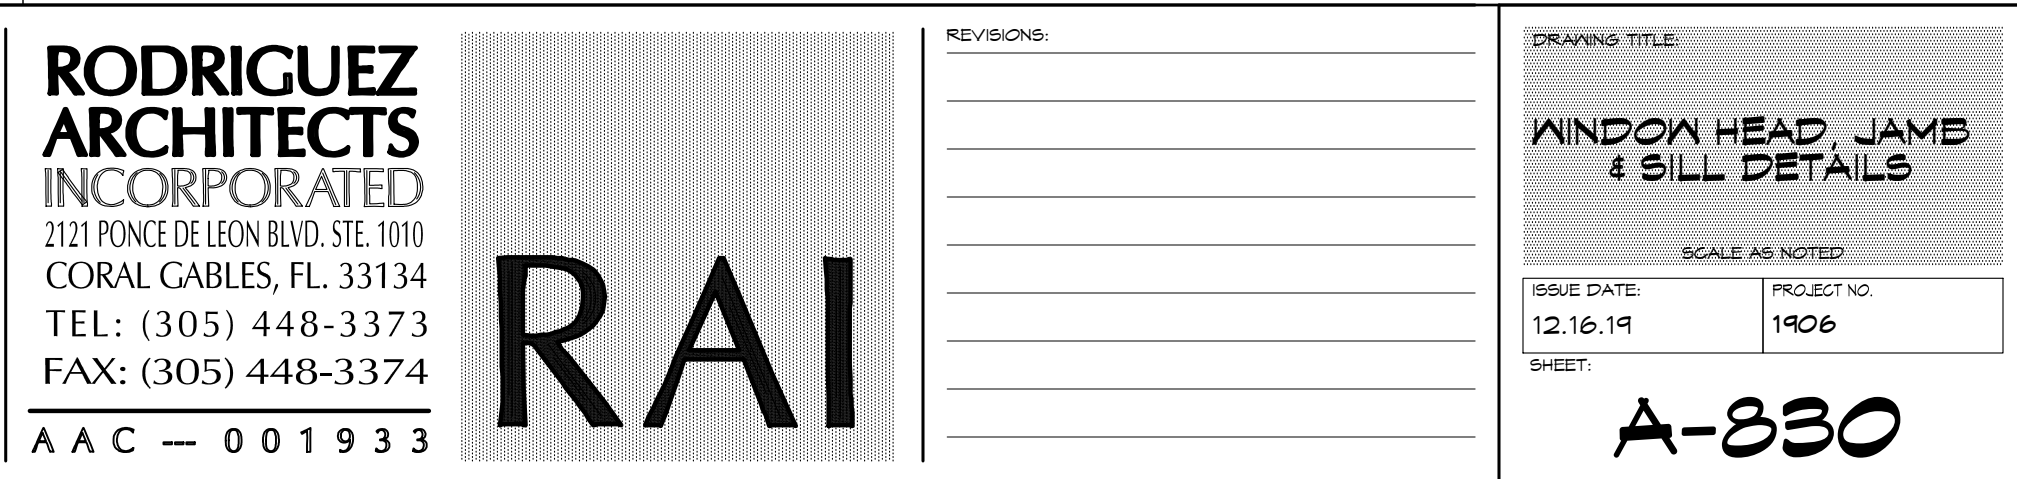

1 **CASEMENT WINDOW - SILL DETAIL - RECESS "C"**
Scale: 3" = 1'-0"

NEW ELEMENTARY SCHOOL (K-5)
VENETIAN PARC WEST
SOUTHWEST 157th AVENUE and 174th STREET
MIAMI, FL. 33187
MDCPS PROJECT No. 01892600

KEY PLAN

CONSULTANT INFO




RODRIGUEZ ARCHITECTS INCORPORATED
2121 PONCE DE LEON BLVD. STE 1010
CORAL GABLES, FL. 33134
TEL: (305) 448-3373
FAX: (305) 448-3374
A A C — 0 0 1 9 3 3

RAI

REVISIONS:

NO.	DATE	DESCRIPTION
1	12/16/19	ISSUED FOR PERMIT

DRAWING TITLE:
WINDOW HEAD, JAMB & SILL DETAILS
SCALE AS NOTED
ISSUE DATE: 12/16/19
PROJECT NO: 1906
SHEET: **A-830**

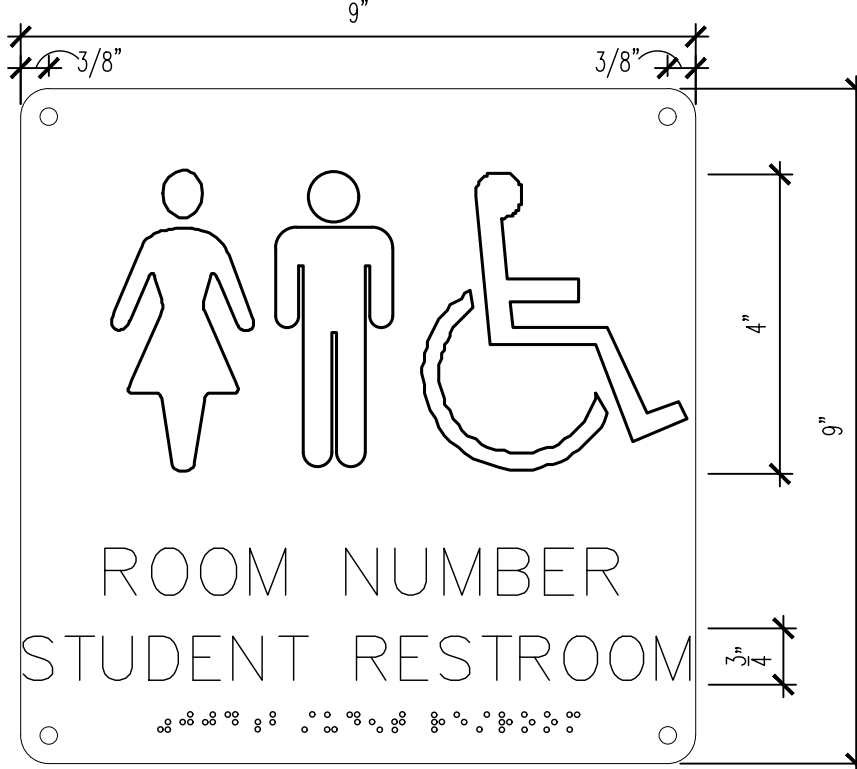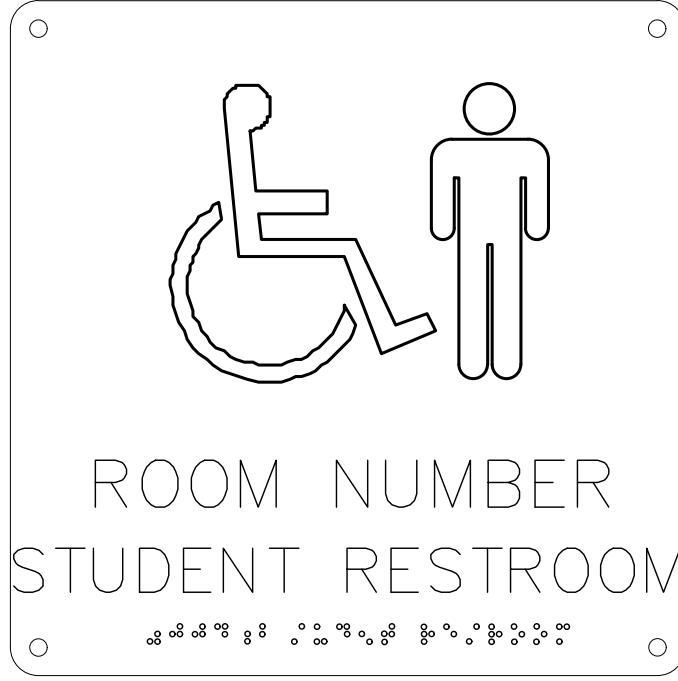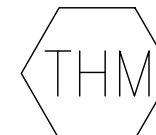HANDICAPPED SIGNS				
<p>PROCESS: GRAPHIC BLAST RAISED $\frac{1}{16}$"</p> <p>MATERIAL: .125" MP PLASTIC</p> <p>MATERIAL FINISH: MATTE</p> <p>EDGE TREATMENT: STANDARD BEVEL</p> <p>CORNER TREATMENT: .375" RADIUS</p> <p>BORDER: N/A</p> <p>COPY SIZE: .75"</p> <p>TYPESTYLE: HELVETICA REGULAR</p> <p>BRAILLE: ROUNDED & PAINTED GRADE II</p> <p>ATTACHMENT: HOLES & ONE-WAY SCREWS, EXPANSION SHIELD VINYL</p> <p>FOAM TAPE</p> <p>LETTER COLOR: 951 WHITE</p> <p>BACKGROUND COLOR: 141 BLUE</p>				
TAG NO.	THB: BOYS BATHROOM		THG: GIRLS BATHROOM	
	TAG NO.		TAG NO.	
	 		 	
DESCRIP.	MOUNTING		TAG NO.	
TOILET ROOM ADA ACCESSIBILITY SIGN, PROVIDE ONE (1) AT ENTRY DOOR/WALL TO EACH TOILET ROOM MEETING ADA CRITERIA		MOUNT SIGN IN ACCORDANCE WITH FLORIDA ACCESSIBILITY CODE, 703.4		

DESCRIPTION	ELECTRICAL ROOM SIGN
<p>PROCESS: GRAPHIC BLAST RAISED $\frac{1}{8}$"</p> <p>MATERIAL: 125" MD PLASTIC</p> <p>MATERIAL FINISH: MATE</p> <p>EDGE TREATMENT: SQUARE (SLIGHT BEVEL FOR PRODUCTION)</p> <p>CORNER TREATMENT: .375" RADIUS</p> <p>COPY SIZE: 1" & #25"</p> <p>TYPESTYLE: HELVETICA REGULAR</p> <p>BRAILLE: ROUNDED & PAINTED GRADE II</p> <p>LETTER COLOR: 951 WHITE</p> <p>BACKGROUND COLOR: 574 RED</p>	

<p>THG: GIRLS BATHROOM</p> <p>TAG NO.</p>	<p>TAG NO.</p>

DESCRIPTION	EXIT ROUTE SIGNS (ER)
EMERGENCY EXIT ROUTE DIAGRAM	
MOUNTING	
AT INSIDE JAMB OF EXIT DOOR OF ALL ROOMS WITH 6 OR MORE PEOPLE	
TAG NO.	

DESCRIPTION	WARNING SIGNS	DESCRIPTION
NO SMOKING SIGN TO BE PLACED AT ENTRY DOOR TO ALL ASSEMBLY SPACES (THESE SPACES MAY BE USED BY OTHERS DURING NON-SCHOOL HOURS)		<p>MOUNTING</p> <p>MOUNTED AT 60° A.F.</p>
MOUNTING		
60° AFF. ADJACENT TO MAIN ENTRY DOORS, AND STAGE ENTRY DOORS		
TAG NO.		TAG NO.

PULL STATION SIGN INFORMATION		
DESCRIPTION	MOUNTING	TAG NUMBER
F.E. AND PULL STATION INSIDE SIGNS: PROVIDE ONE (1) SIGN AT EACH LOCATION INDICATED ON SIGNAGE PLANS	ABOVE THE ROOM NAME SIGN NO HIGHER THAN 72" A.F.F.	

DESCRIPTION		TYP. WARNING SIGN LAYOUT	
<p>PROVIDE APPROPRIATE WARNING SIGNS AT ALL MECHANICAL, ELECTRICAL, COMMUNICATION AND STORAGE ROOMS, INCLUDING ALL LOCATIONS INDICATED ON SIGNAGE PLANS</p>	<p>CONTRAST TO BE MINIMUM 70% BETWEEN BACKGROUND AND TEXT. FINISH TO BE MATTE, EGGSHELL, OR NON GLARE.</p> <p>TEXT COPY 5/8" HIGH, UPPERCASE HELVETICA REGULAR, RAISED 1/32".</p> <p>TEXT TO BE CENTERED IN AREA.</p> <p>GRADE 2 BRAILLE, JUSTIFIED TO COPY, BELOW VERBIAGE.</p>		
MOUNTING			
<p>MOUNT SIGN IN ACCORDANCE WITH FLORIDA ACCESSIBILITY CODE, 703.4</p>			
TAG NO.		WARNING SIGN INFORMATION	
WS1	STORAGE NOT PERMITTED	WS6	EMERGENCY EGRESS KEEP AREA CLEAR
WS2	AUTHORIZED PERSONNEL ONLY	WS7	OCCUPANCY LOAD XXX
WS3	WARNING: ELECTRICAL EQUIPMENT	WS8	MAX OCCUPANCY LOAD XXXX
WS4	EMERGENCY CUT-OFF SWITCH	WS9	AREA OF REFUGE
WS5	STORAGE NOT PERMITTED		

1'-2"

1'-5"

(NAME OF SCHOOL)

Awarded (Month Day, Year)

The School Board of
Miami-Dade County, Florida

First Name Last Name, Chair
First Name Last Name, Vice Chair
First name Middle Initial Last name
First name Middle Initial Last name
First name Middle Initial Last name
First name Middle Initial Last name
First name Middle Initial Last name
First name Middle Initial Last name
First name Middle Initial Last name

First name Middle initial Last Name
Superintendent of Schools

First name Middle initial Last Name
Chief Facilities Officer

Architect: Architect Firm
Contractor: Construction Firm

1/4"

1/2"

1/2"

3/8"

1/4"

3/8"

1/4"

NOTE:
1. PLAQUE TO BE ALUMINUM OR BRONZE.
2. SUBMIT SHOP DRAWINGS FOR APPROVAL OF FONT SIZE, STYLE AND COLOR.
3. SECURE LOGO GRAPHICS FROM OWNER.

ON	AREA OF REFUGE	DESCRIPTION	SECOND NAME
G	<p>8'</p> <p>6'</p> <p>6'</p> <p>AREA OF REFUGE</p> <p>AREA OF REFUGE</p> <p>GRADE 2 BRAILLE, JUSTIFIED TO COPY, BELOW VERBAGE.</p>	<p>SPACE IDENTIFICATION SIGN</p> <p>PROVIDE ONE (1) SIGN AT EACH SECONDARY DOOR LEADING INTO EACH SPACE</p> <p>MOUNTING</p> <p>60" A.F.F. ON THE OUTSIDE OF ROOM AT LOCKSET SIDE OF DOOR JAMB</p>	<p>C.</p> <p>GRAJUS BEL</p>
		<p>TAG NO.</p>	<p>NOTE: INCREASE SIGN WIDTH IN INCREMENTS WHEN SPACE NAME EXCEEDS</p>

SIGN INFORMATION			10 CHARACTERS MAXIMUM SIGN WIDTH OF 12".
	PULL STATION INSIDE		



PROCESS: GRAPHIC BLAST RAISED $\frac{1}{32}$ "
MATERIAL: .25" MP PLASTIC
MATERIAL FINISH: 103 BLACK MATTE
EDGE TREATMENT: SQUARE (SLIGHT BEVEL
FOR PRODUCTION)
CORNER TREATMENT: .375" RADIUS
BORDER: N/A
COPY SIZE: .625" / 1"
TYPESTYLE: HELVETICA REGULAR (951 WHITE)
BRAILLE: ROUNDED & PAINTED GRADE II
SAME COLOR AS BACKGROUND
ATTACHMENT: HOLES & ONE-WAY SCREWS
PLASTIC EXPANSION SHIELDS
VINYL FOAM TAPE

DESCRIPTION	MOUNTING	TAG NO.	SIGN INFO.
VISITORS' SIGN PROVIDE ONE (1) SIGN AT EACH BUILDING ENTRANCE AS SHOWN ON SIGNAGE PLAN	GATES AT 60" A.F.F. ON ALL ENTRY GATES TO THE SCHOOL. MOUNT IN ACCORDANCE WITH FLORIDA ACCESSIBILITY CODE 703.4		ALL VISITORS TO REPORT TO MAIN OFFICE

PROCESS: GRAPHIC BLAST RAISED 3/32"
 MATERIAL: .25" MP PLASTIC
 MATERIAL FINISH: MATTE
 EDGE TREATMENT: SQUARE (SLIGHT BEVEL FOR PRODUCTION)
 CORNER TREATMENT: SQUARE
 BORDER: N/A
 COPY SIZE: 2" & 6"
 TYPESTYLE: HELVETICA REGULAR
 BRaille: N/A
 ATTACHMENT: HOLES & ONE-WAY SCREWS

The diagram shows a rectangular sign with dimensions 15 inches wide by 15 inches high. The top edge has a dimension of 15". The right edge has a total height dimension of 10", which includes three segments: 1" at the top, 8" in the middle, and 1" at the bottom. The left edge has a vertical dimension of 15". The sign features the word "BUILDING" in large, outlined, uppercase letters, followed by a large outlined number "14". There are small circles representing mounting holes at each corner and one near the center of each long side.

BUILDING DIRECTIONAL INFORMATION SIGNS			
DESCRIPTION	MOUNTING	TAG NO.	SIGN INFO.
ADMINISTRATIVE SUITE SIGN PROVIDE ONE (1) SIGN AT THE ENTRY DOOR TO ADMINISTRATION SUITE.	MOUNT 60" A.F.F. OUTSIDE OF ENTRY TO MAIN OFFICE. MOUNT SIGN IN ACCORDANCE WITH FLORIDA ACCESSIBILITY CODE, 703.4, 2017 FFPC (6th EDITION) 4.14.8.3.2	BD1	MAIN OFFICE ADMINISTRATION
ADMINISTRATIVE DIRECTIONAL SIGN PROVIDE ONE (1) SIGN AT MAIN ENTRY DOOR AND ANOTHER SIGN FROM GUIDANCE RECEPTION	MOUNT SIGN IN ACCORDANCE WITH FLORIDA ACCESSIBILITY CODE, 703.4, 2017 FFPC (6th EDITION) 4.14.8.3.2	BD2	ATTENDANCE ADMINISTRATION 
ADMINISTRATIVE DIRECTIONAL SIGN PROVIDE ONE (1) SIGN AT MAIN ENTRY DOOR AND ANOTHER SIGN FROM GUIDANCE RECEPTION	MOUNT 60" A.F.F. OUTSIDE OF ENTRY TO MAIN OFFICE. MOUNT SIGN IN ACCORDANCE WITH FLORIDA ACCESSIBILITY CODE, 703.4, 2017 FFPC (6th EDITION) 4.14.8.3.2	BD3	GUIDANCE RECEPTION ADMINISTRATION
"NOT AN EXIT" SIGN PROVIDE ONE (1) AT THE ENTRY DOOR TO VESTIBULE AT LOCATIONS AS SHOWN ON SIGNAGE PLANS	MOUNT 60" A.F.F. MOUNT SIGN IN ACCORDANCE WITH FLORIDA ACCESSIBILITY CODE, 703.4, 2017 FFPC (6th EDITION) 4.14.8.3.2	BD4	NOT AN EXIT (1" LETTER)
VISITOR ENTRANCE SIGN PROVIDE (1) SIGN AT THE ENTRY TO VISITOR CHECK-IN. SIGN DIMENSIONS: 24"x16". TEXT HEIGHT: 1"	MOUNT 60" A.F.F. MOUNT SIGN IN ACCORDANCE WITH FLORIDA ACCESSIBILITY CODE, 703.4, 2017 FFPC (6th EDITION) 4.14.8.3.2	BD5	VISITOR ENTRANCE FOR THE SAFETY OF THE STUDENTS AND STAFF ALL VISITORS ARE REQUIRED TO ACCESS THE FACILITY THROUGH THIS ENTRANCE
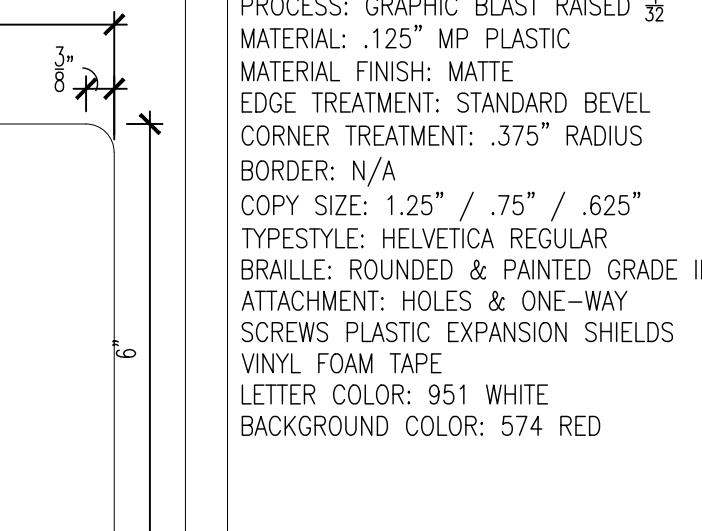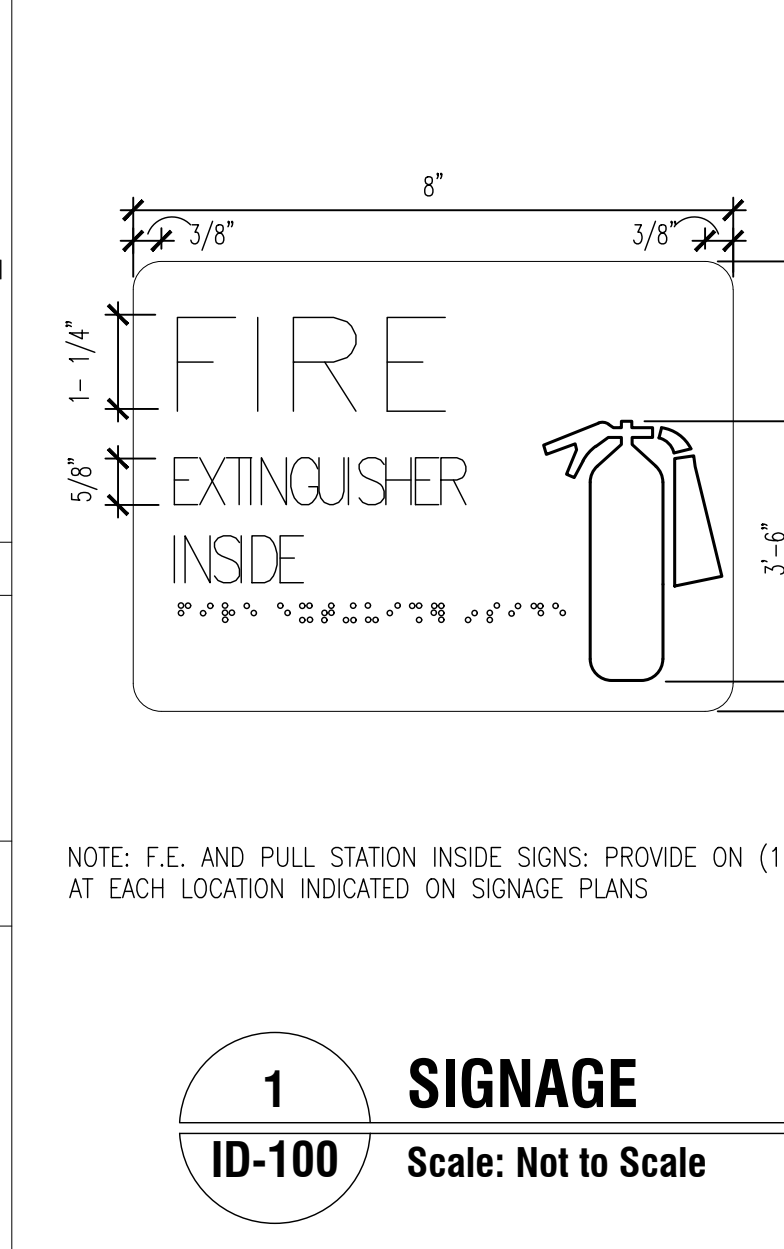
<p>1. ROOM NAME SIGN</p>  <p>8"</p> <p>6"</p> <p>3/8"</p> <p>1/4"</p>	<p>DESCRIPTION</p> <p>PROCESS: GRAPHIC BLAST RAISED $\frac{1}{32}$" MATERIAL: .125" MP PLASTIC MATERIAL FINISH: MATTE EDGE TREATMENT: STANDARD BEVEL CORNER TREATMENT: .375" RADIUS BORDER: N/A COPY SIZE: 1.25" / .75" / .625" TYPESTYLE: HELVETICA REGULAR BRAILLE: ROUNDED & PAINTED GRADE II ATTACHMENT: HOLES & ONE-WAY SCREWS PLASTIC EXPANSION SHIELDS VINYL FOAM TAPE LETTER COLOR: 951 WHITE BACKGROUND COLOR: 574 RED</p> <p>MOUNTING</p> <p>ABOVE THE ROOM NAME SIGN NO HIGHER THAN 72" A.F.F.</p>	<p>TAG NO.</p> 	<p>FIRE EXTINGUISHER SIGNS (FE)</p>  <p>8"</p> <p>3/8"</p> <p>1/4"</p> <p>6"</p> <p>3/8"</p> <p>1/4"</p> <p>FIRE</p> <p>EXTINGUISHER</p> <p>INSIDE</p> <p>NOTE: F.E. AND PULL STATION INSIDE SIGNS: PROVIDE ON (1) SIGN AT EACH LOCATION INDICATED ON SIGNAGE PLANS</p> <p>1</p> <p>ID-100</p> <p>SIGNAGE</p> <p>Scale: Not to Scale</p>
--	--	--	--

CHECKED BY:
LR

DRAWN BY:
C.V.

MIAMI-DADE COUNTY
giving our students
the world
PUBLIC SCHOOLS

NEW ELEMENTARY SCHOOL (K-5)
VENETIAN PARC WEST
SOUTHWEST 157th AVENUE and 174th STREET
MIAMI, FL. 33187
MDCPS PROJECT No. 01892600

KEY PLAN

A

B

CONSULTANT INFO:

FLOOR AREA: 10,000 SQ. FT.
FLOOR REGISTRATION TAX: \$600

RODRIGUEZ
ARCHITECTS
INCORPORATED
2121 PONCE DE LEON BLVD., STE. 1010
CORAL GABLES, FL. 33134
TEL: (305) 448-3373
FAX: (305) 448-3374
AAC — 001933

RAI

REVISIONS:

DRAWING TITLE:

SIGNAGE DETAILS


SCALE AS NOTED

BASIC DATE
12.16.19

PROJECT NO.
1906

SHEET:

ID-100

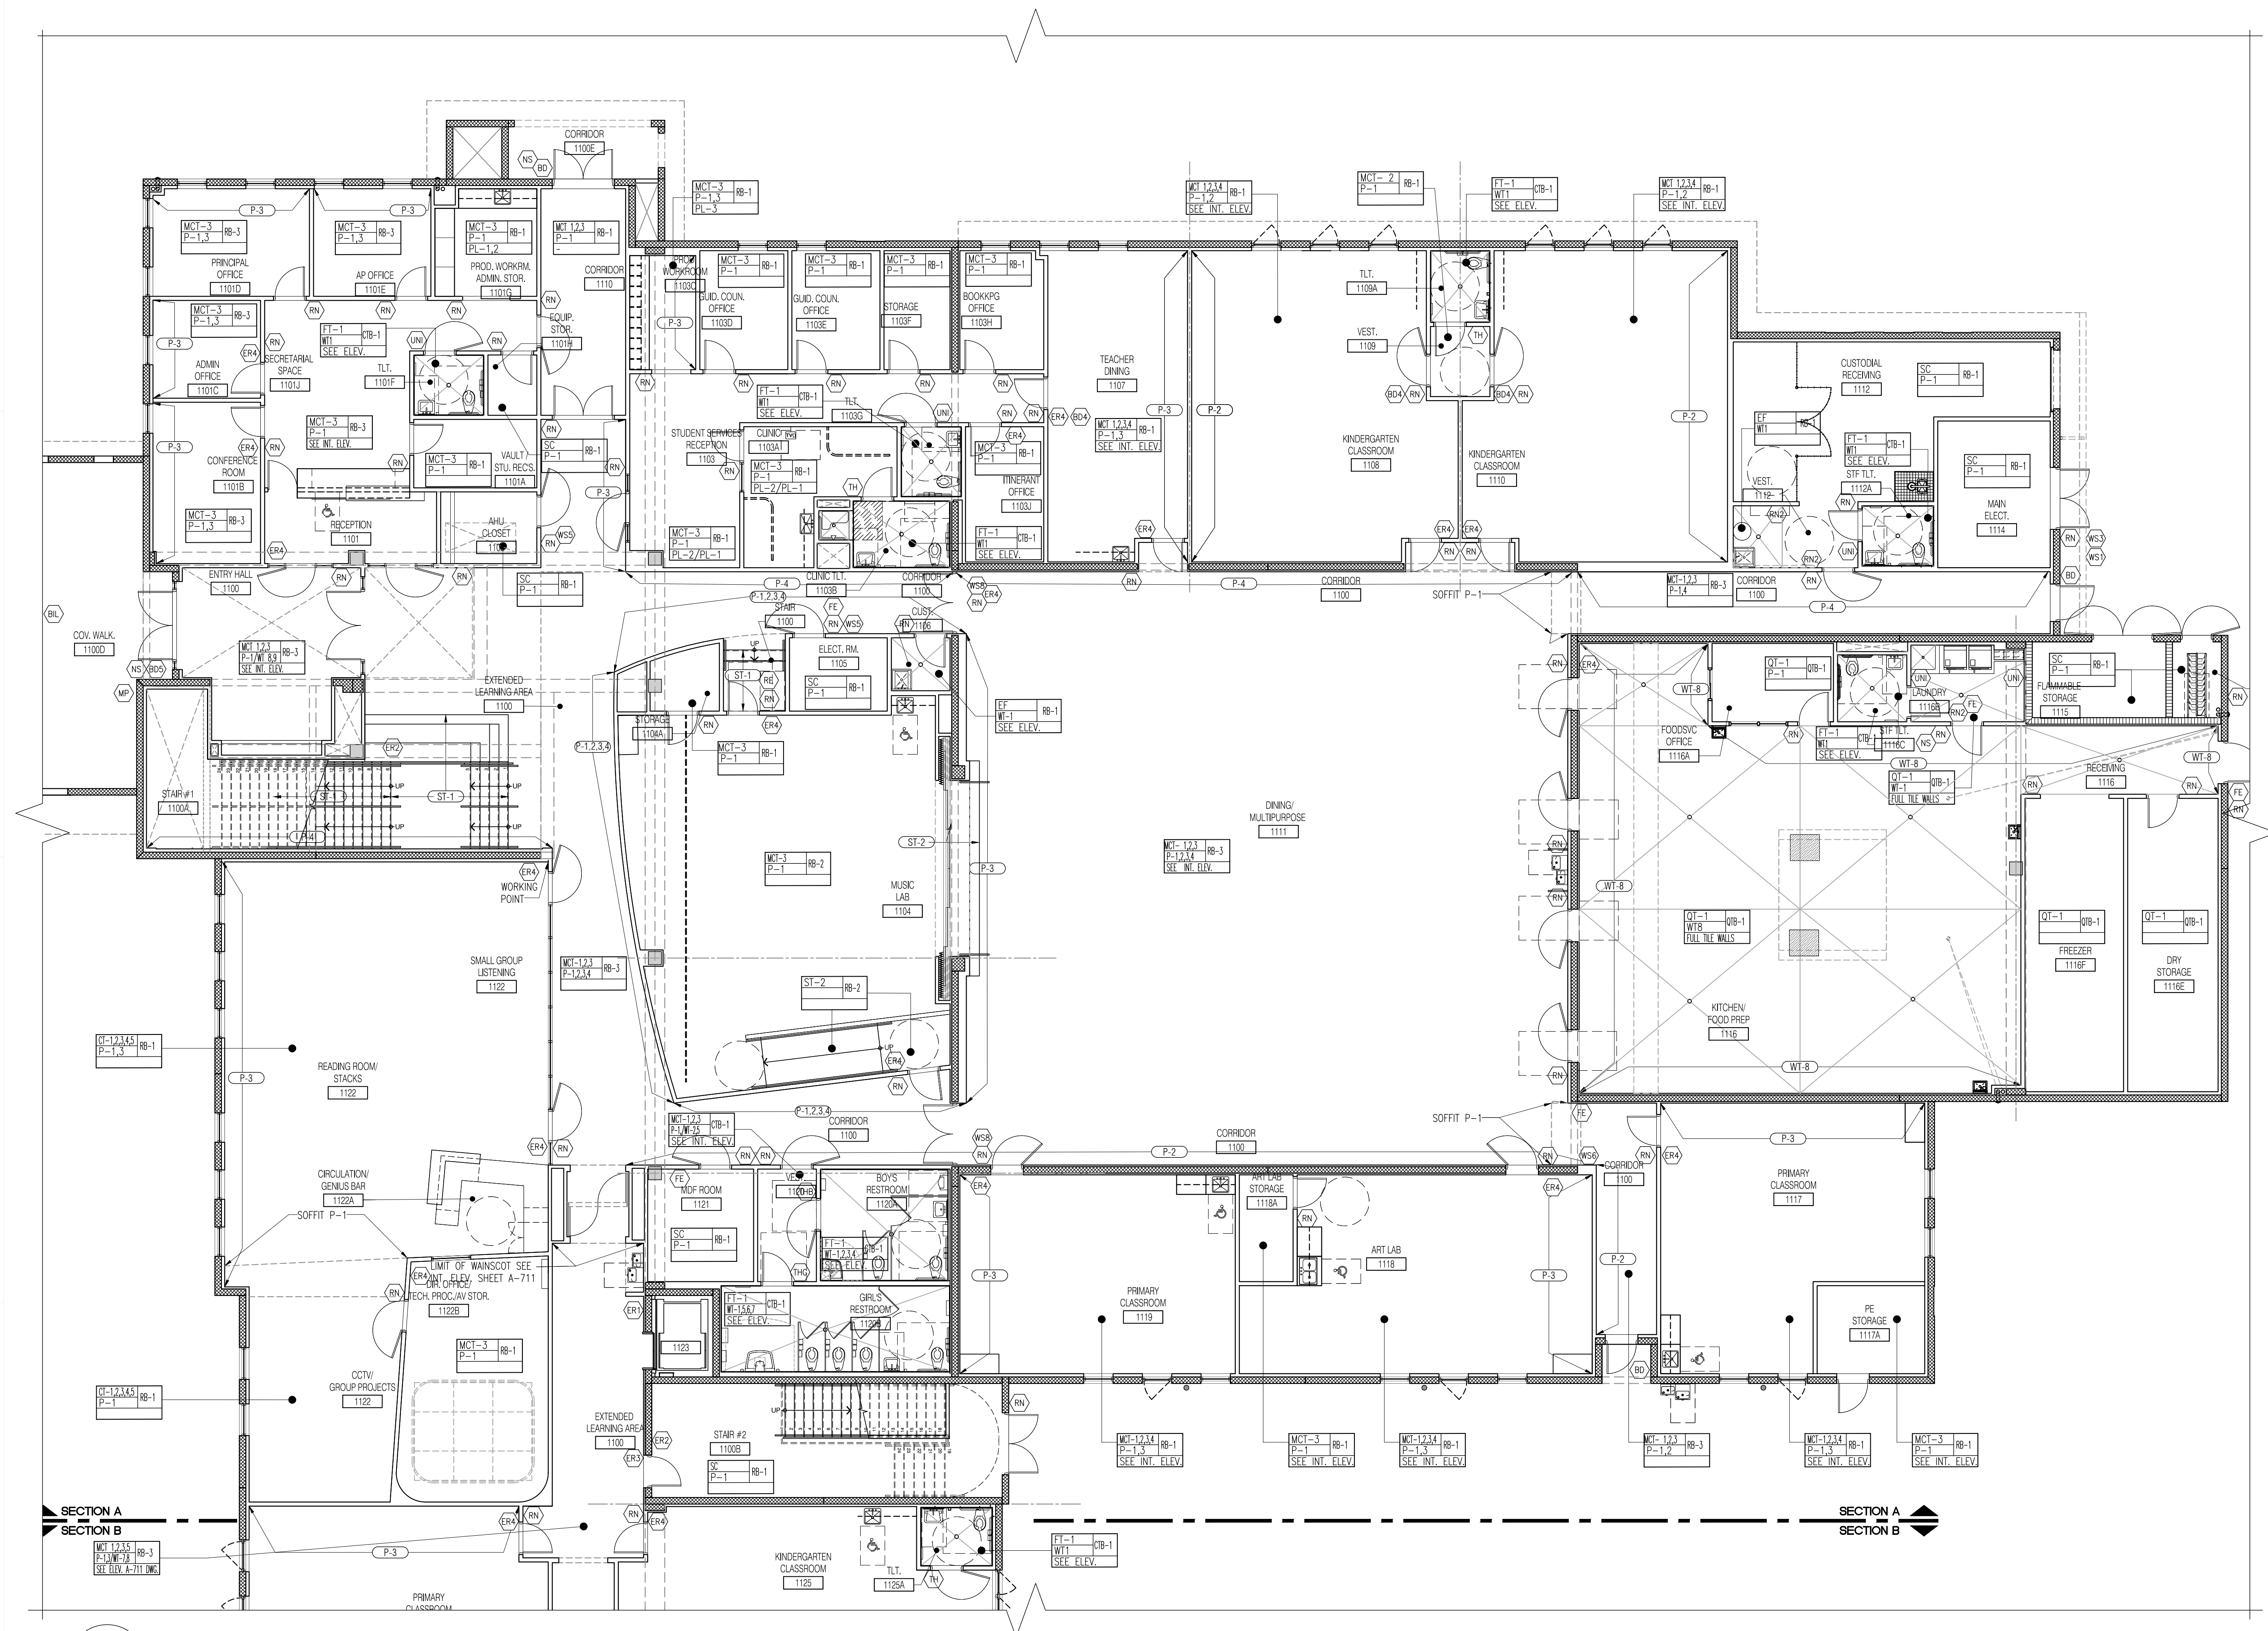

1 ENLARGED FIRST FLOOR FINISH & SIGNAGE PLAN - AREA A
ID-211 Scale: 1/8" = 1'-0"

FINISH KEY							
WALL BASE	SC	100	100	100	100	100	100
FLOOR FINISH	SC	100	100	100	100	100	100
WALL FINISH	SC	100	100	100	100	100	100
CABINETRY	SC	100	100	100	100	100	100



FINISH SCHEDULE							
MARK	DESCRIPTION	MFG	STYLE/FINISH	COLOR	SIZE	LOCATION	NOTES
FLOORING							
FT-1	PORCELAIN TILE	MOSA	G.COLLECTION/SATIN	75620	12" x 12"	ALL BATHROOM	
CT-1	CARPET TILE	INTERFACE	ON LINE/	103780 STONE	9" x 36"	MEDIA CENTER	
CT-2	CARPET TILE	INTERFACE	ON LINE/	103780 LAPS	9" x 36"	MEDIA CENTER	
CT-3	CARPET TILE	INTERFACE	ON LINE/	103780 LIME	9" x 36"	MEDIA CENTER	
CT-4	CARPET TILE	INTERFACE	ON LINE/	103803 MANDARIN	9" x 36"	MEDIA CENTER	
CT-5	CARPET TILE	INTERFACE	ON LINE/	103802 CANARY	9" x 36"	MEDIA CENTER	
MT-1	MARMOLEUM COMPOSITION TILE	FORBO		MT-3629 PROSTY GREY	13" x 13"	CLASSROOMS AND CORRIDORS	
MT-2	MARMOLEUM COMPOSITION TILE	FORBO		MT-3238 LAGUNA	13" x 13"	CLASSROOMS AND CORRIDORS	
MT-3	MARMOLEUM COMPOSITION TILE	FORBO		MT-3601 WARM GREY	13" x 13"	CLASSROOMS AND CORRIDORS	
MT-4	MARMOLEUM COMPOSITION TILE	FORBO		MT-3243 STUCCO ROSE	13" x 13"	CLASSROOMS AND CORRIDORS	
MT-5	MARMOLEUM COMPOSITION TILE	FORBO		MT-3655 ORQUID GREEN	13" x 13"	CLASSROOMS AND CORRIDORS	
ST-1	RUBBER STAIR TREADS	JOHNSONITE	CUBES/ CUTR-80	80 FAWN		SEE ID SHEETS	
ST-2	RUBBER STAIR TREADS	JOHNSONITE	CUBES/ CUTR-63	63 BURNT UMBER B		SEE ID SHEETS	
QT-1	QUARRY TILE	DALTILE	QUARRY TILE	ARID GRAY Q042	6" x 6"	KITCHEN AREA/STORAGE	REFER TO ID DOWS
EF	EPOXY FLOOR	INUR-A-FLEX				SEE ID SHEETS	REFER TO SPECIFICATIONS
SC	SEALED CONCRETE					SEE ID SHEETS	
BASE							
RB-1	RUBBER BASE	JOHNSONITE		32 PEBBLE WG	4"	MTYP. ALL THROUGH	REFER TO SPECIFICATIONS
RB-2	RUBBER BASE	JOHNSONITE		40 BLACK B	4"	MUSIC LAB	REFER TO ID DRAWINGS
RB-3	RUBBER BASE	JOHNSONITE	EQUINOX PROFILE	32 PEBBLE WG	4"H-3/8" GAUGE	SEE ID SHEETS	REFER TO ID DRAWINGS
CTB-1	CERAMIC COVE BASE TILE					ALL BATHROOMS	WITH EPOXY GROUT
QTB-1	QUARRY TILE	DALTILE	QUARRY TILE	ARID GRAY Q042	6" x 6"	KITCHEN AREA/STORAGE	REFER TO ID DOWS
WALLS							
WT-1	CERAMIC WALL TILE	MOSA	G.COLLECTION/SATIN	15220	4" x 12"	ALL BATHROOM	
WT-2	CERAMIC WALL TILE	MOSA	COLORS/SATIN	20910	4" x 12"	ALL BATHROOM	
WT-3	CERAMIC WALL TILE	MOSA	COLORS/SATIN	17900	4" x 12"	ALL BATHROOM	
WT-4	CERAMIC WALL TILE	MOSA	COLORS/SATIN	19910	4" x 12"	ALL BATHROOM	
WT-5	CERAMIC WALL TILE	MOSA	G.COLLECTION/SATIN	16950	4" x 12"	ALL BATHROOM	
WT-6	CERAMIC WALL TILE	MOSA	G.COLLECTION/SATIN	16980	4" x 12"	ALL BATHROOM	
WT-7	CERAMIC WALL TILE	MOSA	COLORS/SATIN	17960	4" x 12"	ALL BATHROOM	
WT-8	CERAMIC WALL TILE	MOSA	MURALS BLEND/SATIN	31050	12" x 24"	CORRIDOR	
WT-9	CERAMIC WALL TILE	MOSA	MURALS BLEND/SATIN	33250	12" x 24"	CORRIDOR	
AW-1	ACOUSTICAL WALL PANEL	GULFORD OF MAINE	ANCHORAGE 2335	MOX 2027		DINING AREA	SEE SPEC. CORE PANEL
AW-2	ACOUSTICAL WALL PANEL	GULFORD OF MAINE	ANCHORAGE 2335	GREEN APPLE 2087		DINING/MUSIC LAB/TYP. ALL AREAS	REFER TO ID DRAWINGS
P-1	PAINT-FIELD	BENJAMIN MOORE	EGGSHELL	HC-170 STONINGTON GRAY		TYPICAL ALL AREAS	
P-2	PAINT-ACCENT	BENJAMIN MOORE	EGGSHELL	2027-30 ECCENTRIC LIME		KINDERGARTEN CLRM/DINING AREA	REFER TO ID DRAWINGS
P-3	PAINT-ACCENT	BENJAMIN MOORE	EGGSHELL	2016-30 CARROT STICK		PRIMARY CLRM/DINING AREA/OFFICE	REFER TO ID DRAWINGS
P-4	PAINT-ACCENT	BENJAMIN MOORE	EGGSHELL	2054-40 BLUE JACOBIN		INTERMEDIATE CLRM /DINING AREA	REFER TO ID DRAWINGS
P-5	PAINT-ACCENT	BENJAMIN MOORE	EGGSHELL	AC-27 GALVESTON GRAY		ALL DOORS	
P-6	PAINT	BENJAMIN MOORE	EGGSHELL	PM-1 SUPER WHITE		ALL GWN. CEILINGS	REFER TO ID DRAWINGS
EW	EPOXY WALL	PPG	DEASCAPES			WET AREAS	REFER TO ID DRAWINGS
MILLWORK							
SS-1	SOLID SURFACE	CORIAN		WHIPPED CREAM		SEE ELEV. DWGS.	SEE ELEV. DWGS.
PL-1	PLASTIC LAMINATE	FORMICA	MATTE FINISH	WEATHERED ASH		SEE ELEV. DWGS.	SEE ELEV. DWGS.
PL-2	PLASTIC LAMINATE	FORMICA	MATTE FINISH	GRANITE		SEE ELEV. DWGS.	SEE ELEV. DWGS.
PL-3	PLASTIC LAMINATE	FORMICA	MATTE FINISH	TERRIL		SEE ELEV. DWGS.	SEE ELEV. DWGS.
OTHERS							
TP-1	TOILET PARTITION	WILSONART		WP STRANDZ 493K-18		ELEVATOR	
EP-1	ELEVATOR PANEL	WILSONART		WP STRANDZ 493K-18		MUSIC RM. STAGE/DINING AREA	REFER TO SPEC.
FB-1	STAGE CURTAIN FABRIC	KM FABRICS		1366 EGGSHELL		WINDOWS	REFER TO SPEC.12490
WS-1	WINDOW SHADES	MECHOSHADE 500PCL	ECOVELL 1350 SERIES			WINDOWS AND DOORS	REFER TO RCP DWGS.
MT-1	MIL FRAME WINDOWS/DOORS	KANNER	ANNODIZED	N618 CHAMPAGNE		SEE ID SHEETS	
COB-1	GYPSON BOARD PAINTED	LATICRETE		39 MUSHROOM		SEE ID SHEETS	
EG-1	EPOXY GROUT	LATICRETE		24 NATURAL GREY		SEE ID SHEETS	
EG-2	EPOXY GROUT	LATICRETE		24 NATURAL GREY		SEE ID SHEETS	
EG-3	EPOXY GROUT	LATICRETE		24 NATURAL GREY		SEE ID SHEETS	
EXTERIOR PAINT							
P-20	EXTERIOR PAINT	BENJAMIN MOORE	EGGSHELL	2167-60 SWEET SALMON		SEE EXTERIOR ELEVATION	
P-21	EXTERIOR PAINT	BENJAMIN MOORE	EGGSHELL	2167-40 TOFFEE ORANGE		SEE EXTERIOR ELEVATION	
P-22	EXTERIOR PAINT	BENJAMIN MOORE	EGGSHELL	2167-40 PEANUT SHELL		SEE EXTERIOR ELEVATION	
P-23	EXTERIOR PAINT	BENJAMIN MOORE	EGGSHELL	AC-27 GALVESTON GRAY		SEE EXTERIOR ELEVATION	

GENERAL NOTES
1. FOR ALL CEILING FINISHES REFER TO REFLECTED CEILING PLANS SHEETS A-311 THRU A-322.
2. ALL INTERIOR FINISHES SHALL COMPLY WITH THE REQUIRED CLASSIFICATION AS DESCRIBED IN THE FLORIDA FIRE CODE PREVENTION CODE. ALL INTERIOR FINISHES TO BE CLASS "A".
3. EPOXY PAINT TO BE PROVIDED ON ALL WALLS AND CEILINGS IN ALL WET AREAS ABOVE CERAMIC TILE.
4. ALL GYPSON BOARD CEILINGS AND SOFFITS TO BE PAINTED CEILING WHITE.
5. CONTRACTOR TO COORDINATE WITH ARCHITECT FOR FINAL COLOR PATTERNS AND DESIGNATIONS WITH FINAL APPROVED MATERIALS.
6. FOR FLOOR PATTERNS REFER TO TOILET EDGE OR COUNTERTOP BASE CABINET AS WORKING POINT.
7. FINAL FLOOR PATTERNS TO BE DETERMINED BY ARCHITECT AND ID.
8. FOR ALL THE WAINSCOT AT TILE BASE INSTALL "L" ALUMINUM EDGE




GENERAL NOTES


1. FOR ALL CEILING FINISHES REFER TO REFLECTED CEILING PLANS SHEETS A-311 THRU A-322.
2. ALL INTERIOR FINISHES SHALL COMPLY WITH THE REQUIRED CLASSIFICATION AS DESCRIBED IN THE FLORIDA FIRE CODE PREVENTION CODE. ALL INTERIOR FINISHES TO BE CLASS "1," MINIMUM FLAME/SMOKE SPREAD RATING FOR ALL INTERIOR FINISHES SHALL BE IN ACCORDANCE WITH FBC TABLE 803.9.
3. CEILING TO BE PROVIDED ON ALL WALLS AND CEILINGS IN ALL "WET" AREAS ABOVE CERAMIC TILE.
4. ALL GYPSUM BOARD CEILINGS AND JOISTS TO BE PAINTED CEILING WHITE.
5. CONTRACTOR TO COORDINATE WITH ARCHITECT FOR FINAL COLOR PATTERNS & DESIGNATIONS WITH FINAL APPROVED MATERIALS.
6. FOR FLOOR PATTERN REFER TO TOILET EDGE OR COUNTERTOP BASE CABINET AS WORKING POINT.
7. FLOOR PATTERN TO BE DETERMINED BY ARCHITECT AND I.D.
8. FOR ALL THE WAINSCOT AT THE BASE INSTALL 1" ALUMINUM EDGE

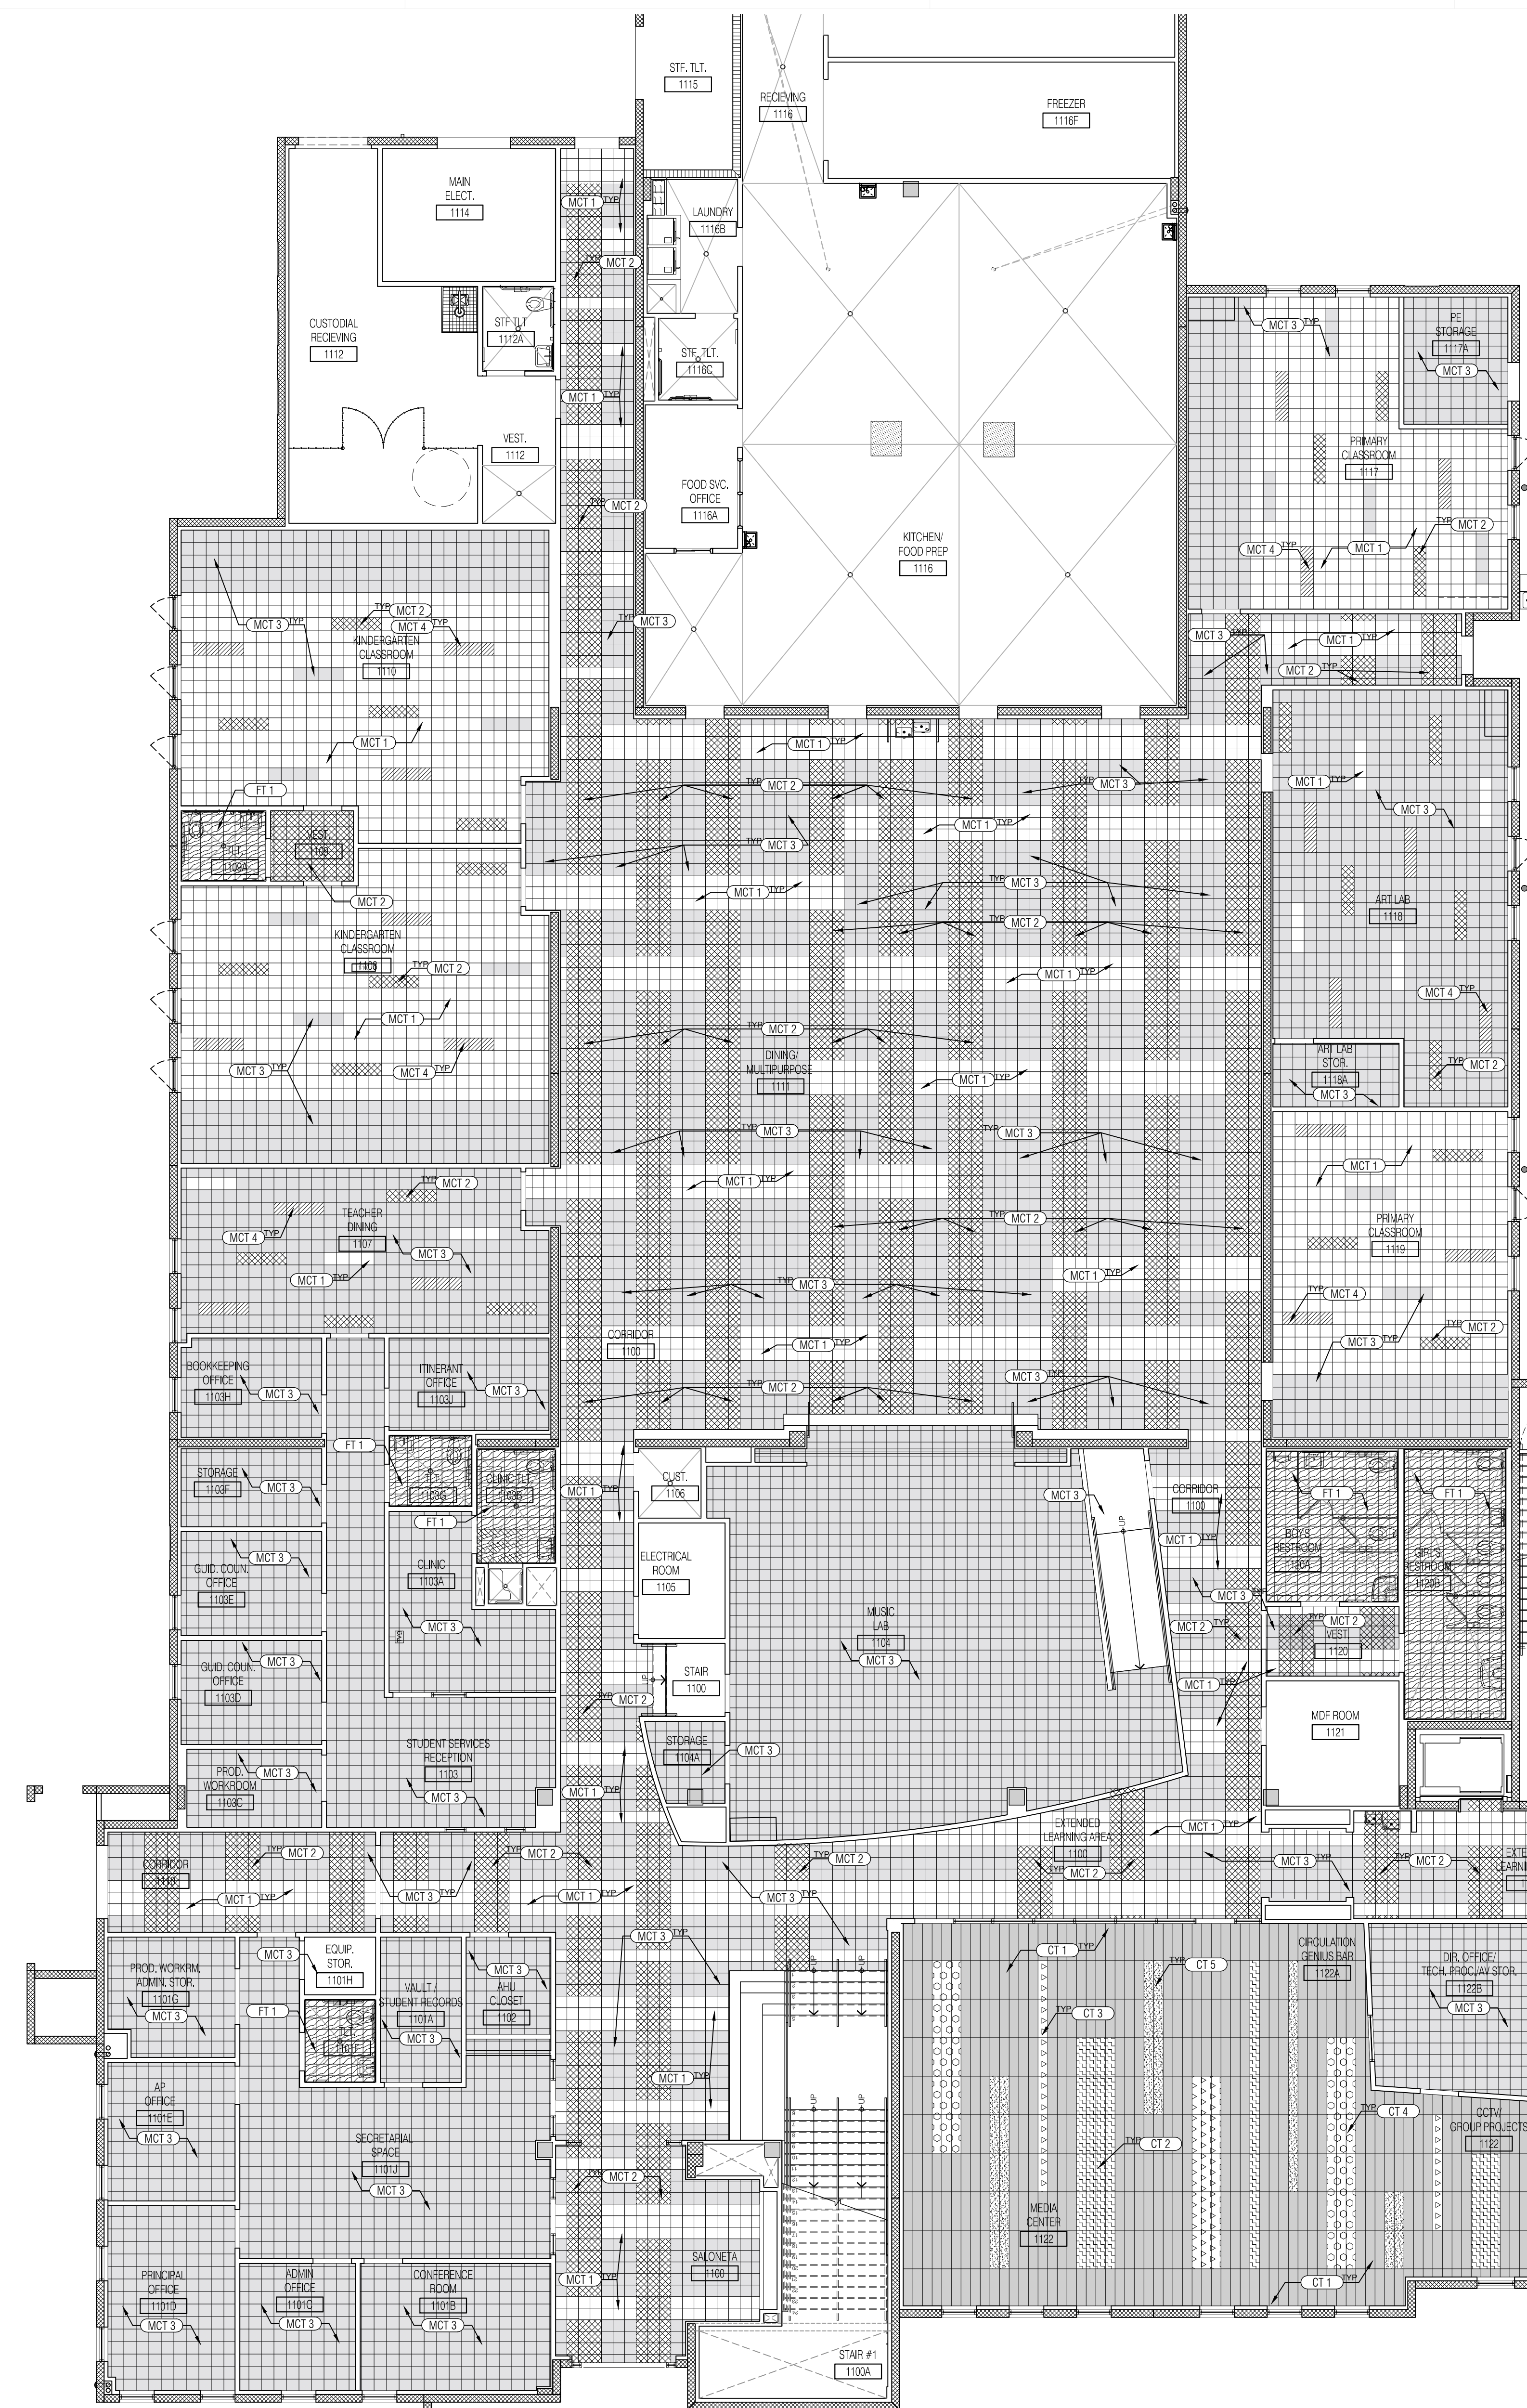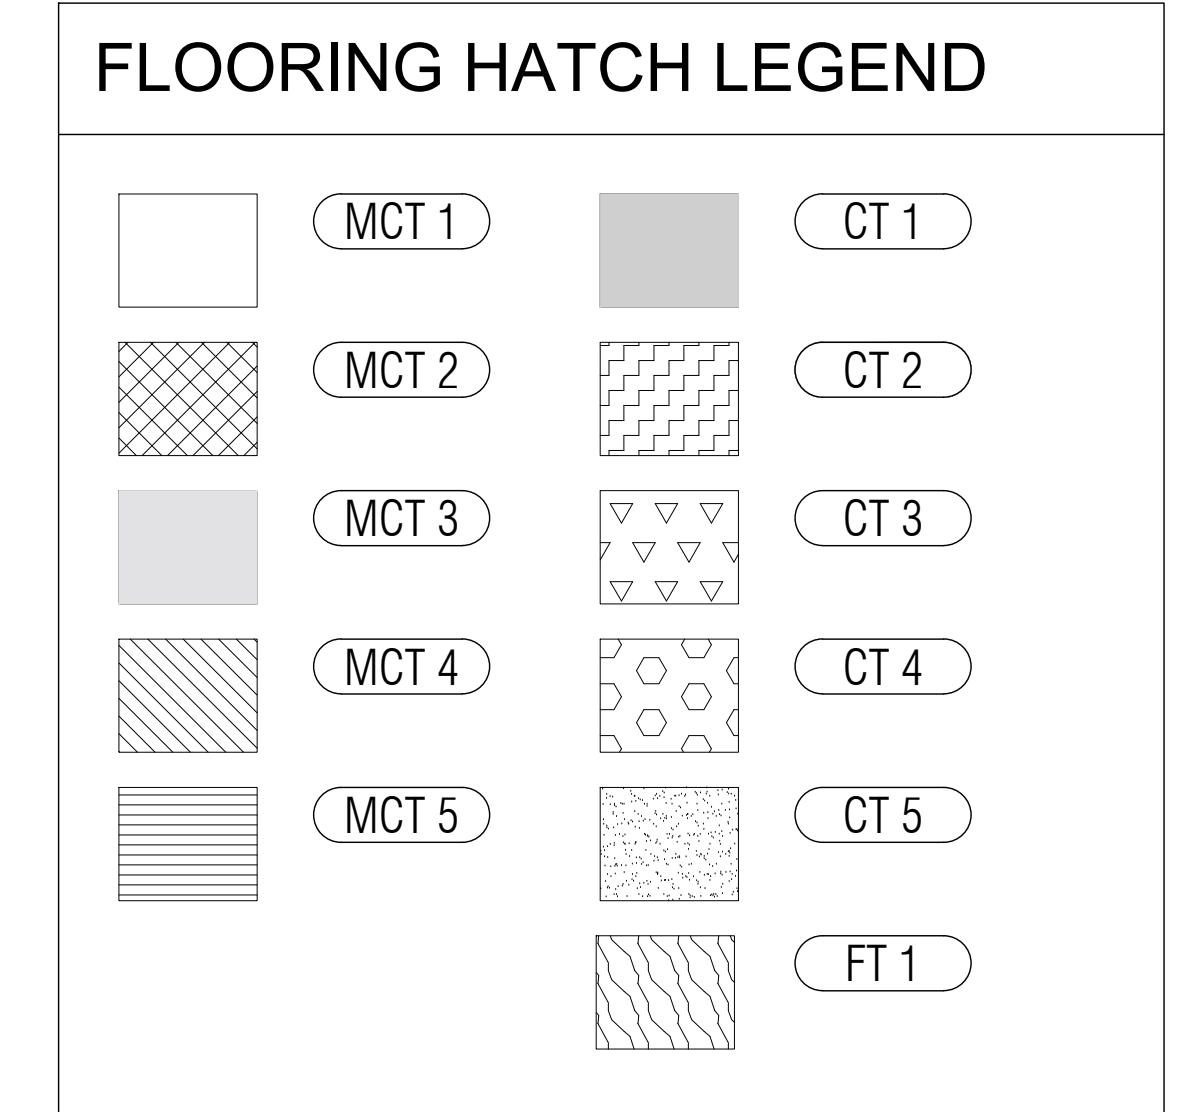

1 OVERALL FIRST FLOOR PATTERN

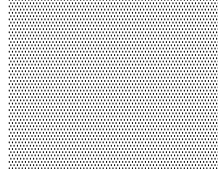

	
CHECKED BY: LR.	DRAWN BY: C.V.

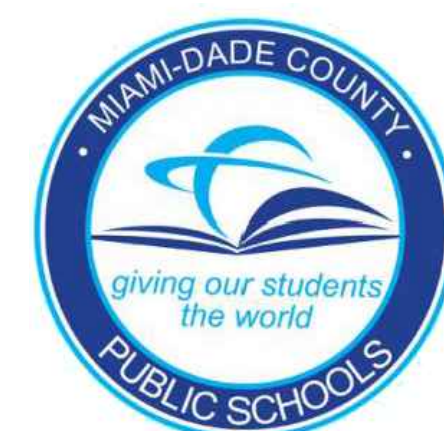


NEW ELEMENTARY SCHOOL (K-5)


VENETIAN PARC WEST

SOUTHWEST 157th AVENUE and 174th STREET
MIAMI, FL. 33187

MDCPS PROJECT No. 01892600

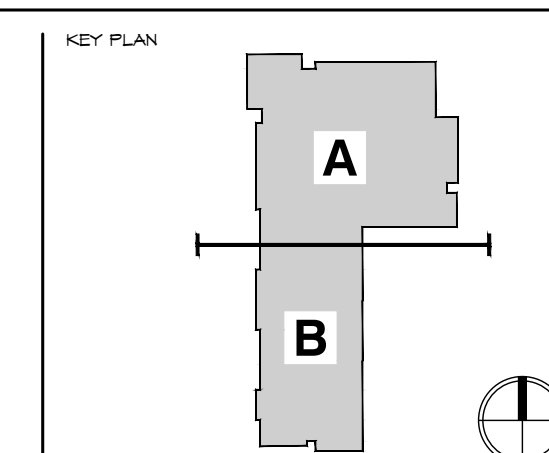

CONSULTANT INFO

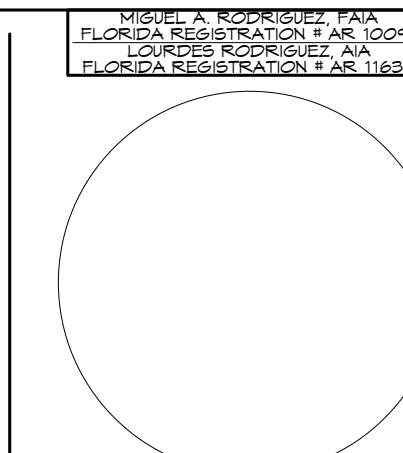


**RODRIGUEZ
ARCHITECTS
INCORPORATED**
2121 PONCE DE LEON BLVD, STE. 1010
CORAL GABLES, FL. 33134
TEL: (305) 448-3373
FAX: (305) 448-3374
A A C — 0 0 1 9 3 3

RA

REVISIONS

DRAWING TITLE:	
OVERALL FIRST FLOOR PATTERN	
SCALE AS NOTED	
DATE: 1.16.19	PROJECT NO. 1906
SHEET:	
D-213	

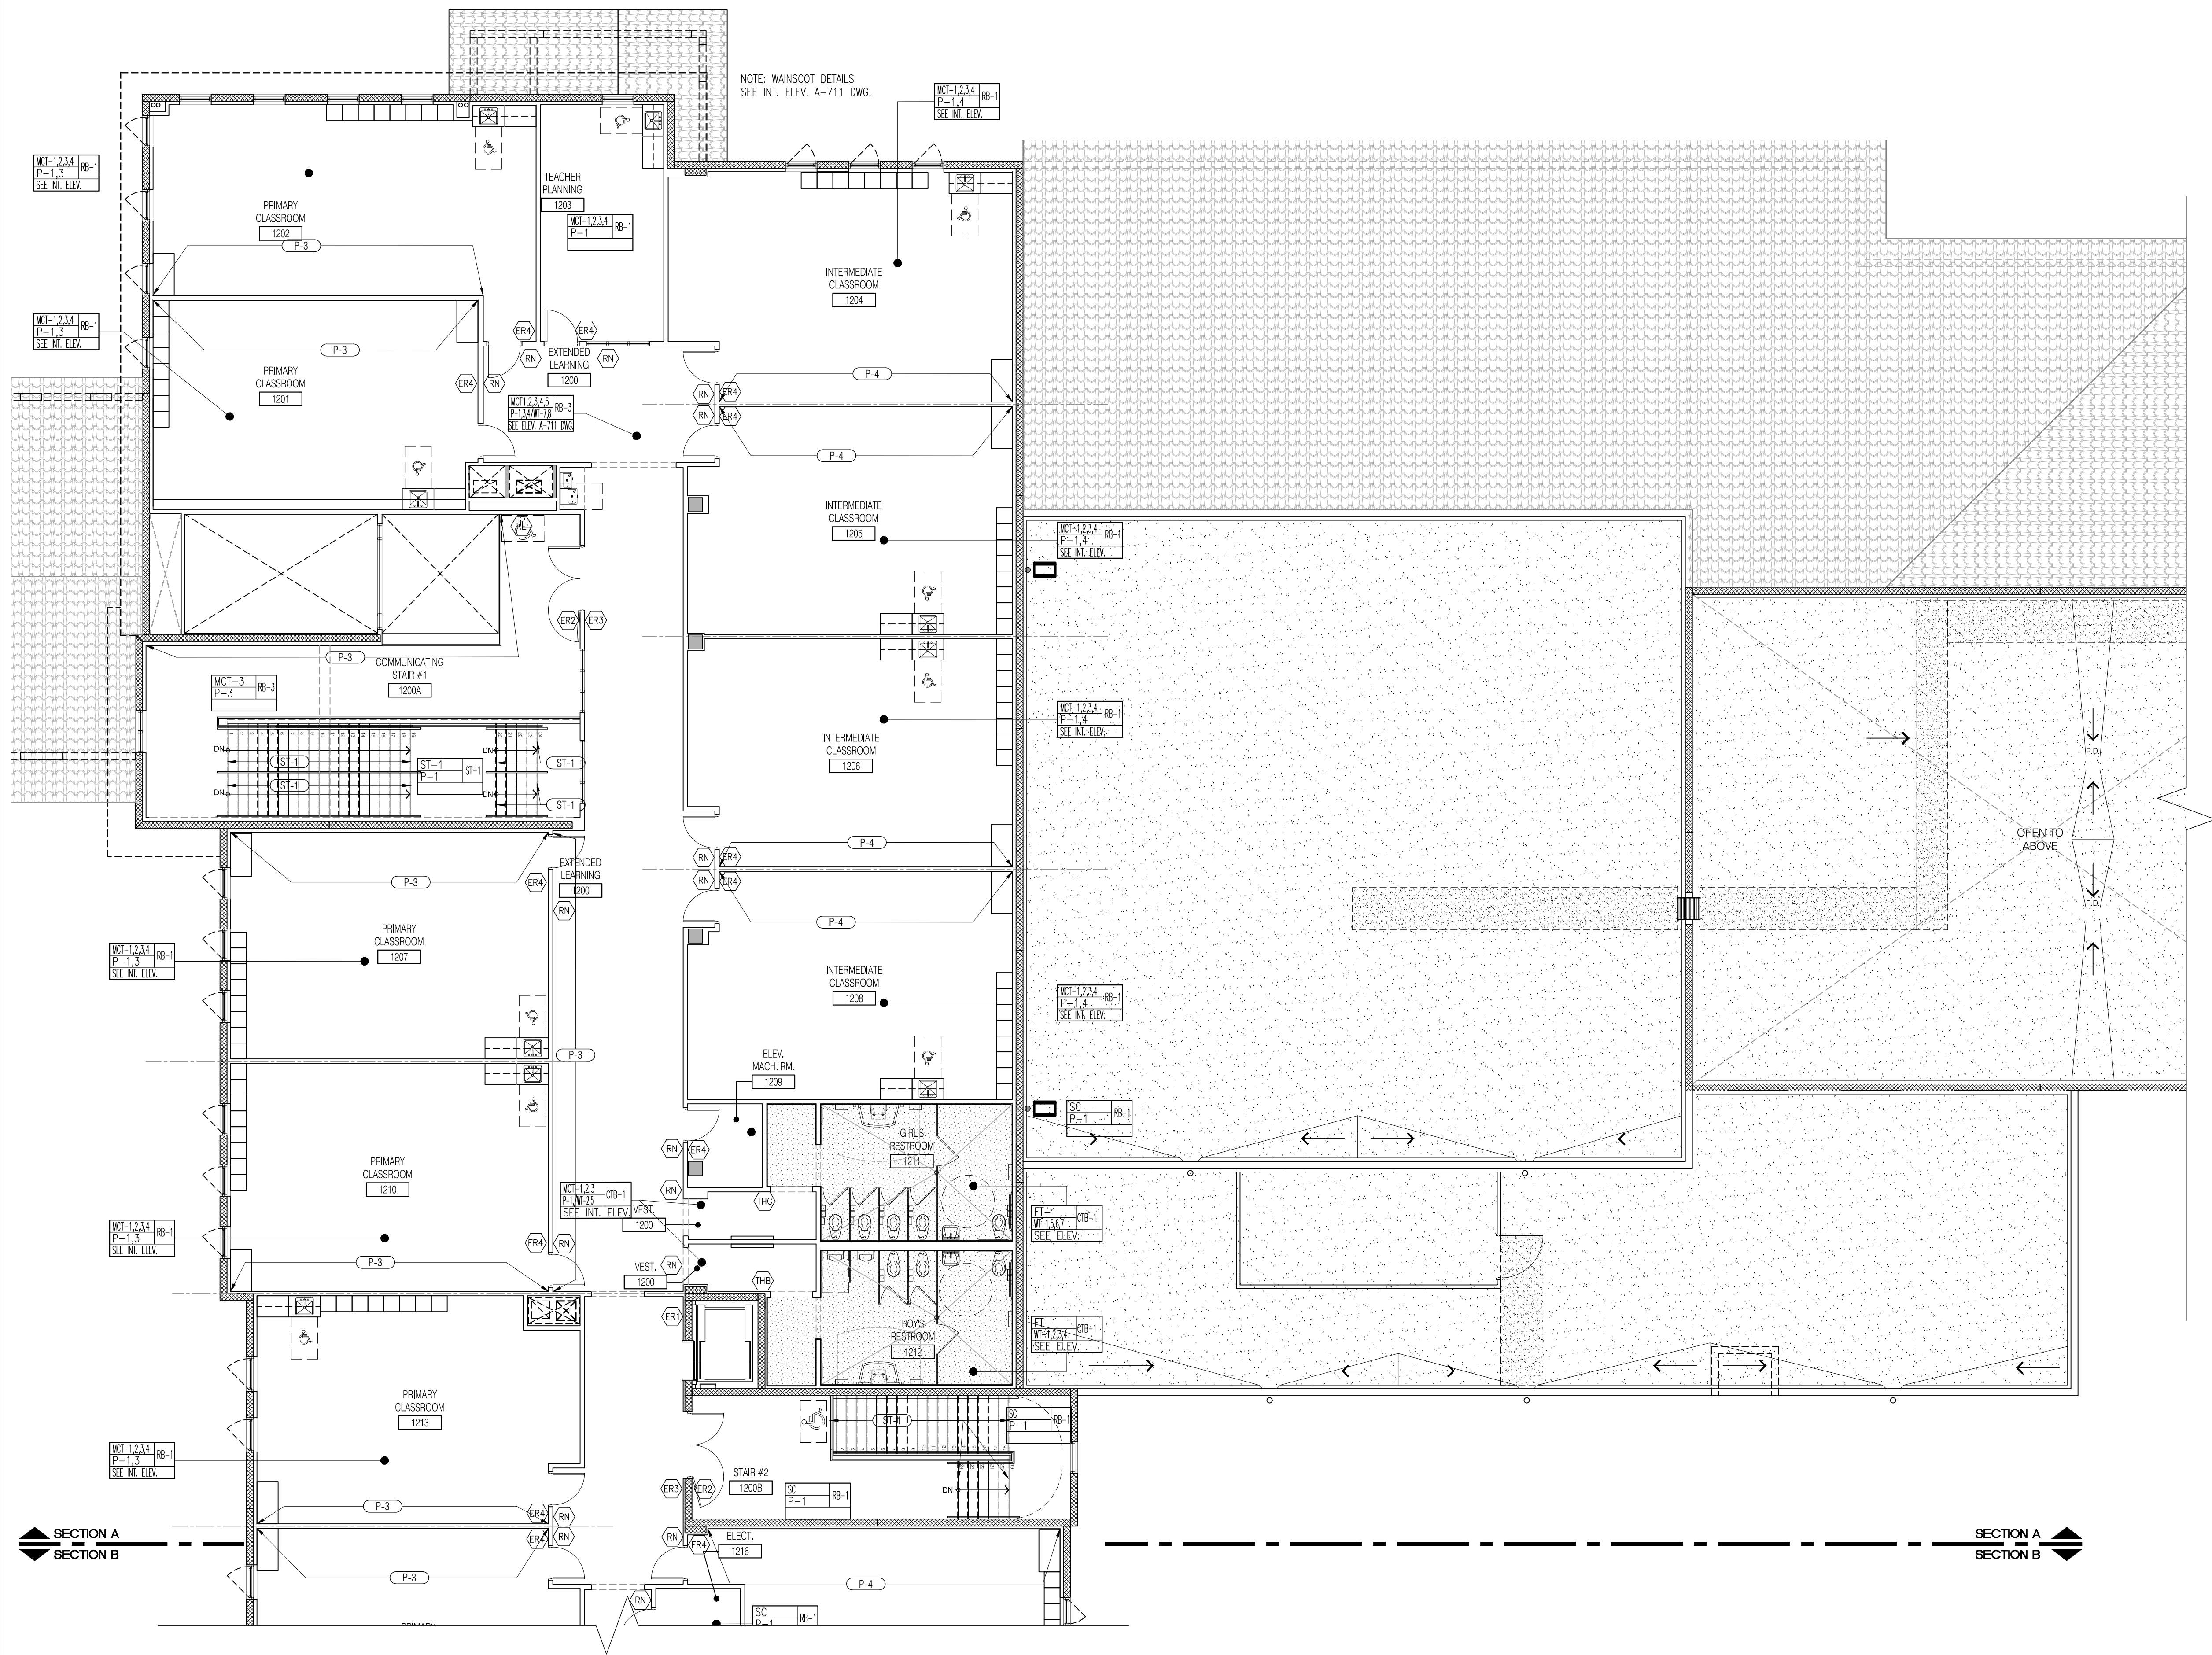

FINISH KEY

WALL BASE	→	ISC	WB
FLOOR FINISH	→	PF	FB
WALL FINISH	→	WF	WB
CABINETRY	→	CTOP	CB

FINISH SCHEDULE

MARK	DESCRIPTION	MFG	STYLE/FINISH	COLOR	SIZE	LOCATION	NOTES
FLOORING							
FT-1	PORCELAIN TILE	MOSA	G.COLLECTION/SATIN	P5620	12" x 12"	ALL BATHROOM	
CT-1	CARPET TILE	INTERFACE	ON LINE/	103790 STONE	9" x 39"	MEDIA CENTER	
CT-2	CARPET TILE	INTERFACE	ON LINE/	103799 LAPS	9" x 39"	MEDIA CENTER	
CT-3	CARPET TILE	INTERFACE	ON LINE/	103798 LIME	9" x 39"	MEDIA CENTER	
CT-4	CARPET TILE	INTERFACE	ON LINE/	103803 MANDARIN	9" x 39"	MEDIA CENTER	
CT-5	CARPET TILE	INTERFACE	ON LINE/	103802 CANARY	9" x 39"	MEDIA CENTER	
MCT-1	MARMOLEUM COMPOSITION TILE	FORBO		MCT-3628 FROSTY GREY	13" x 13"	CLASSROOMS AND CORRIDORS	
MCT-2	MARMOLEUM COMPOSITION TILE	FORBO		MCT-3238 JAGUNA	13" x 13"	CLASSROOMS AND CORRIDORS	
MCT-3	MARMOLEUM COMPOSITION TILE	FORBO		MCT-3601 WARM GREY	13" x 13"	CLASSROOMS AND CORRIDORS	
MCT-4	MARMOLEUM COMPOSITION TILE	FORBO		MCT-3243 STUCCO ROSE	13" x 13"	CLASSROOMS AND CORRIDORS	
MCT-5	MARMOLEUM COMPOSITION TILE	FORBO		MCT-3655 GROUND GREEN	13" x 13"	CLASSROOMS AND CORRIDORS	
ST-1	RUBBER STAIR TREADS	JOHNSONITE	CURBS/ CUTR-80	R3 BURNT LUMBER B		SEE ID SHEETS	
ST-2	RUBBER STAIR TREADS	JOHNSONITE	CURBS/ CUTR-63	R3 BURNT LUMBER B		SEE ID SHEETS	
QT-1	QUARRY TILE	DALITILE	QUARRY TILE	ARD GRAY 0042	6" x 6"	KITCHEN AREA/STORAGE	REFER TO ID DWGS
EF	EPOXY FLOOR	DUP-A-FLEX		028-23		SEE ID SHEETS	REFER TO SPECIFICATIONS
SC	SEALED CONCRETE					SEE ID SHEETS	REFER TO SPECIFICATIONS

BASE							
RB-1	RUBBER BASE	JOHNSONITE		32 PEBBLE WG	4"	TYP. ALL THROUGH	REFER TO SPECIFICATIONS
RB-2	RUBBER BASE	JOHNSONITE		40 BLACK B	4"	MUSIC LAB	REFER TO ID DRAWINGS
RB-3	RUBBER BASE	JOHNSONITE	EQUINOX PROFILE	32 PEBBLE WG	4"11-3/8 GAUGE	SEE ID SHEETS	REFER TO ID DRAWINGS
CTB-1	CERAMIC COVE BASE TILE					ALL BATHROOMS	WITH EPOXY GROUT
QTB-1	QUARRY TILE	DALITILE	QUARRY TILE	ARD GRAY 0042	6" x 6"	KITCHEN AREA/STORAGE	REFER TO ID DWGS

WALLS							
WT-1	CERAMIC WALL TILE	MOSA	G.COLLECTION/SATIN	15220	4" x 12"	ALL BATHROOM	
WT-2	CERAMIC WALL TILE	MOSA	COLORS/SATIN	20910	4" x 12"	ALL BATHROOM	
WT-3	CERAMIC WALL TILE	MOSA	G.COLLECTION/SATIN	17900	4" x 12"	ALL BATHROOM	
WT-4	CERAMIC WALL TILE	MOSA	COLORS/SATIN	19910	4" x 12"	ALL BATHROOM	
WT-5	CERAMIC WALL TILE	MOSA	G.COLLECTION/SATIN	16950	4" x 12"	ALL BATHROOM	
WT-6	CERAMIC WALL TILE	MOSA	G.COLLECTION/SATIN	16980	4" x 12"	ALL BATHROOM	
WT-7	CERAMIC WALL TILE	MOSA	COLORS/SATIN	17950	4" x 12"	ALL BATHROOM	
WT-8	CERAMIC WALL TILE	MOSA	MURALS BLEND/SATIN	31050	12" x 24"	CORRIDOR	
WT-9	CERAMIC WALL TILE	MOSA	MURALS BLEND/SATIN	33250	12" x 24"	CORRIDOR	
AW-1	ACOUSTICAL WALL PANEL	GULFORD OF MAINE	ANCHORAGE 2335	WOLF 2027		DINING AREA	SEE SPEC. CORE PANEL
AW-2	ACOUSTICAL WALL PANEL	GULFORD OF MAINE	ANCHORAGE 2335	GREEN APPLE 2087		DINING/MUSIC LAB	REFER TO ID DRAWINGS
P-1	PAIN-FIELD	BENJAMIN MOORE	EGGSHELL	HC-170 STONINGTON GRAY		TYPICAL ALL AREAS	REFER TO ID DRAWINGS
P-2	PAIN-ACCENT	BENJAMIN MOORE	EGGSHELL	2027-30 ECCENTRIC LIME		KINDERGARDEN CLRM/DINING AREA	REFER TO ID DRAWINGS
P-3	PAIN-ACCENT	BENJAMIN MOORE	EGGSHELL	2016-30 CARROT STICK		PRIMARY CLRM/DINING AREA/OFFICE	REFER TO ID DRAWINGS
P-4	PAIN-ACCENT	BENJAMIN MOORE	EGGSHELL	2054-40 BLUE LAGOON		INTERMEDIATE CLRM/DINING AREA	REFER TO ID DRAWINGS
P-5	PAIN-ACCENT	BENJAMIN MOORE	EGGSHELL	AC-27 GALVESTON GRAY		ALL DOORS	
P-6	PAIN	BENJAMIN MOORE	EGGSHELL	PM-1 SUPER WHITE		ALL DMB. CEILINGS	REFER TO ID DRAWINGS
EW	EPOXY WALL	PPG-IDEASCAPES				WET AREAS	REFER TO ID DRAWINGS

MILLWORK							
SS-1	SOLID SURFACE	CORIAN		WHIPPED CREAM		SEE ELEV. DWGS.	SEE ELEV. DWGS.
PL-1	PLASTIC LAMINATE	FORMICA	MATTE FINISH	WEATHERED ASH		SEE ELEV. DWGS.	SEE ELEV. DWGS.
PL-2	PLASTIC LAMINATE	FORMICA	MATTE FINISH	GRAYSTONE		SEE ELEV. DWGS.	SEE ELEV. DWGS.
PL-3	PLASTIC LAMINATE	FORMICA	MATTE FINISH	TERRIL		SEE ELEV. DWGS.	SEE ELEV. DWGS.

OTHERS							
TP-1	TOILET PARTITION					ELEVATOR	
EP-1	ELEVATOR PANEL	MILSONART		MP STRANDZ 4939K-18		MUSIC RM. STAGE/DINING AREA	REFER TO SPEC. 12490
FB-1	STAGE CURTAIN FABRIC	KW FABRICS		1064 BLACK		WINDOWS	
WS-1	WINDOW SHADES	MECHOSHADE S/KOPEN	ECOVELL 1350 SERIES	1366 EGGSHELL		WINDOWS AND DOORS	
MT-1	MTL FRAME WINDOWS/DOORS	KAWNEER	ANNODIZED	N6.18 CHAMPAGNE		WINDOWS AND DOORS	REFER TO RCP DWGS.
COB-1	GYPSON BOARD PAINTED		FLAT	CEILING WHITE		REFER TO RCP DWGS.	
EG-1	EPOXY GROUT	LATICRETE		39 MUSHROOM		SEE ID SHEETS	
EG-2	EPOXY GROUT	LATICRETE		24 NATURAL GREY		SEE ID SHEETS	
EG-3	EPOXY GROUT	LATICRETE		AS FINISH BOARD		SEE ID SHEETS	

EXTERIOR PAINT							
P-20	EXTERIOR PAINT	BENJAMIN MOORE	EGGSHELL	2167-60 SWEET SALMON		SEE EXTERIOR ELEVATION	
P-21	EXTERIOR PAINT	BENJAMIN MOORE	EGGSHELL	2167-40 TOFFEE ORANGE		SEE EXTERIOR ELEVATION	
P-22	EXTERIOR PAINT	BENJAMIN MOORE	EGGSHELL	2162-40 PEANUT SHELL		SEE EXTERIOR ELEVATION	
P-23	EXTERIOR PAINT	BENJAMIN MOORE	EGGSHELL	AC-27 GALVESTON GRAY		SEE EXTERIOR ELEVATION	

GENERAL NOTES

1. FOR ALL CEILING FINISHES REFER TO REFLECTED CEILING PLANS SHEETS A-311 THRU A-322.
2. ALL INTERIOR FINISHES SHALL COMPLY WITH THE REQUIRED CLASSIFICATION AS DESCRIBED IN THE FLORIDA FIRE CODE PREVENTION CODE. ALL INTERIOR FINISHES TO BE CLASS "A". MINIMUM FLAME/SMOKE SPREAD RATING FOR ALL INTERIOR FINISHES SHALL BE IN ACCORDANCE WITH FBC TABLE 803.8.
3. EPOXY PAINT TO BE PROVIDED ON ALL WALLS AND CEILINGS IN ALL WET AREAS ABOVE CERAMIC TILE.
4. ALL GYPSUM BOARD CEILINGS AND SOFFITS TO BE PAINTED CEILING WHITE.
5. CONTRACTOR TO COORDINATE WITH ARCHITECT FOR FINAL COLOR PATTERNS AND DESIGNATIONS WITH FINAL APPROVED MATERIALS.
6. FOR FLOOR PATTERN REFER TO TOILET CODE OR COUNTERTOP BASE CABINET AS WORKING PATTERN.
7. FINAL FLOOR PATTERN TO BE DETERMINATE BY ARCHITECT AND ID.
8. FOR ALL THE WANSOT AT TILE BASE INSTALL "L" ALUMINUM EDGE

1 ENLARGED SECOND FLOOR FINISH & SIGNAGE PLAN - AREA A
ID-221 Scale: 1/8"= 1'-0"


CHECKED BY: LR	DRAWN BY: CV
-------------------	-----------------

CONSULTANT INFO:



NEW ELEMENTARY SCHOOL (K-5)
VENETIAN PARC WEST
SOUTHWEST 157th AVENUE and 174th STREET
MIAMI, FL. 33187
MDCPS PROJECT No. 01892600

KEY PLAN

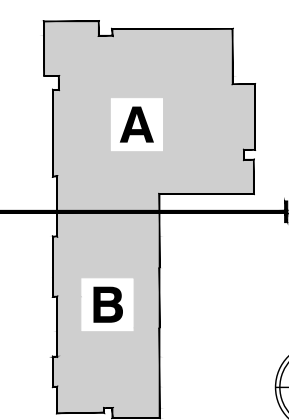

CONSULTANT INFO:

DESIGN & CONSTRUCTION
FLORIDA REGISTERED ARCHITECT
PROJECT NO. 01892600

RODRIGUEZ ARCHITECTS INCORPORATED
2121 PONCE DE LEON BLVD. STE 1010
CORAL GABLES, FL. 33134
TEL: (305) 448-3373
FAX: (305) 448-3374
A A C — 0 0 1 9 3 3

RAI

REVISIONS:

DRAWING TITLE:	
ENL. 2ND FLOOR FINISH & SIGNAGE AREA A	
SCALE AS NOTED	
ISSUE DATE: 2.16.19	PROJECT NO: 1906
SHEET:	
ID-221	



GENERAL NOTES	
1.	FOR ALL CEILING FINISHES REFER TO REFLECTED CEILING PLANS SHEETS A-31 THRU A-32.
2.	ALL INTERIOR FINISHES SHALL COME V WITH THE REQUIRED CLASSIFICATION AS DESCRIBED IN THE FLORIDA FIRE CODE PREVENTION CODE. ALL INTERIOR FINISHES TO BE CLASS "A" MINIMUM FLAME-SMOKING SPREAD RATING FOR ALL INTERIOR FINISHES SHALL BE IN ACCORDANCE WITH TABLE F803.9.
3.	EPOXY PAINT TO BE PROVIDED ON ALL WALLS AND CEILINGS IN ALL WET AREAS ABOVE CERAMIC TILE.
4.	FOR SQUARED CEILINGS AND GYPTIS TO BE PAINTED CEILING WHITE.
5.	CONTRACTOR TO COORDINATE WITH ARCHITECT FOR FINAL COLOR PATTERNS & DESIGNATIONS WITH FINAL APPROVED MATERIALS.
6.	FOR FLOOR PATTERN REFER TO TOILET EDGE OR COUNTERTOP BASE CABINET AS WORKING POINT.
7.	FOR FLOOR PATTERN TO BE DETERMINATE BY ARCHITECT AND ID.
8.	FOR ALL THE WANSOAT AT TILE BASE INSTALL "L" ALUMINUM EDGE

FLOORING HATCH LEGEND

	MCT 1		CT 1
	MCT 2		CT 2
	MCT 3		CT 3
	MCT 4		CT 4
	MCT 5		CT 5
			FT 1

1 OVERALL SECOND FLOOR PATTERN ID-223 Scale: 1/8" = 1'-0"




CHECKED BY: LR	DRAWN BY: CV
-------------------	-----------------

CONSULTANT INFO:



NEW ELEMENTARY SCHOOL (K-5)
VENETIAN PARC WEST
SOUTHWEST 157th AVENUE and 174th STREET
MIAMI, FL. 33187
MDCPS PROJECT No. 01892600

KEY PLAN

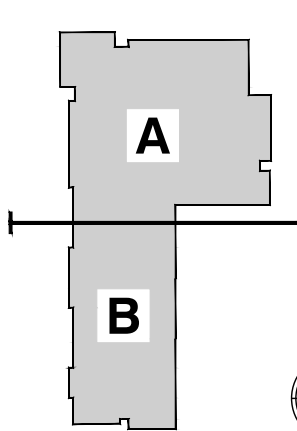

CONSULTANT INFO:

RODRIGUEZ ARCHITECTS, INC.
2121 PONCE DE LEON BLVD., STE. 1010
CORAL GABLES, FL. 33134
TEL: (305) 448-3373
FAX: (305) 448-3374
A A C - 0 0 1 9 3 3

RODRIGUEZ ARCHITECTS INCORPORATED
2121 PONCE DE LEON BLVD., STE. 1010
CORAL GABLES, FL. 33134
TEL: (305) 448-3373
FAX: (305) 448-3374
A A C - 0 0 1 9 3 3

RAI

REVISIONS:

ISSUE DATE:
12/16/14
SHEET:
1906
ID-223

GENERAL NOTES

DIMENSIONS SHOWN ARE FOR DESIGN PURPOSES ONLY AND ARE TO BE CONSIDERED FROM FINISHED WALLS. ALL DIMENSIONS GIVEN MUST BE FIELD VERIFIED BY THE KITCHEN EQUIPMENT CONTRACTOR BEFORE FINAL PLANS ARE SUBMITTED.

THESE DRAWINGS ARE INTENDED TO BE USED IN CONJUNCTION WITH THE WRITTEN FOODSERVICE EQUIPMENT SPECIFICATIONS AS WRITTEN BY INMAN FOODSERVICES GROUP AND IN COORDINATION WITH ARCHITECTURAL/ENGINEERING DRAWINGS AS AN AD TO ALL CONTRACTORS INVOLVED WITH FOODSERVICE EQUIPMENT.

INDICATED MECHANICAL, ELECTRICAL AND PLUMBING INFORMATION AND OUTLETS HAVE BEEN LOCATED AS ACCURATELY AS CAN BE DETERMINED AND ARE INTENDED TO SUIT REQUIREMENTS OF FIXTURES AND EQUIPMENT AS SPECIFIED IN THIS CONTRACT DOCUMENT SET. INMAN FOODSERVICES GROUP SHALL NOT BE RESPONSIBLE FOR ANY DISCREPANCIES WHICH MAY DEVELOP BETWEEN LOCATIONS OF CONNECTIONS SHOWN AND ACTUAL LOCATIONS OF CONNECTIONS OF FIXTURES FURNISHED.

CONNECTIONS SHOWN ON THESE PLANS ARE APPROXIMATE LOCATIONS ON FIXTURES, EXCEPT WHERE OTHERWISE NOTED AND ALLOWANCES MUST BE MADE FOR TRAPS, VALVES, SWITCHES OR OTHER CONNECTION REQUIREMENTS SO AS NOT TO INTERFERE WITH THE OPERATION OF ITEMS OF FOODSERVICE EQUIPMENT.

KITCHEN EQUIPMENT CONTRACTOR SHALL FURNISH THE DIMENSIONED EQUIPMENT LAYOUT PLAN AND MECHANICAL, ELECTRICAL, AND PLUMBING ROUGH-IN DRAWINGS AS PER THE WRITTEN SPECIFICATIONS AS DETAILED UNDER 1.2.2 SUBMITTALS REQUIREMENTS AND APPROVALS.

THE KITCHEN EQUIPMENT CONTRACTOR SHALL BE RESPONSIBLE FOR ANY DISCREPANCIES BETWEEN THE CONNECTIONS SHOWN HEREIN AND THOSE REQUIRED FOR THE ACTUAL EQUIPMENT FURNISHED AS A RESULT OF SUBSTITUTIONS OR CHANGES INITIATED BY THE KITCHEN EQUIPMENT CONTRACTOR. THE KITCHEN EQUIPMENT CONTRACTOR SHALL BE RESPONSIBLE FOR ANY AND ALL RE-ENGINEERED OR REDESIGN COSTS INCURRED BY SAID SUBSTITUTIONS OR CHANGES.

CONNECTIONS, LOADS AND CONSUMPTIONS SHOWN ON UTILITY CONNECTION PLANS ARE FOR ONE UNIT. TO DETERMINE TOTAL REQUIREMENTS MULTIPLY BY NUMBER IN EQUIPMENT SPECIFICATIONS.

CONSUMPTION RATES SHOWN ON CONNECTION PLANS ARE MAXIMUM RATES ONLY. ACTUAL CONSUMPTION WILL DEPEND UPON THE TOTAL HOURS THE VARIOUS EQUIPMENT ITEMS ARE OPERATED.


ALL WALK-IN COOLER/FREEZER ASSEMBLIES TO MEET U.S. FLAME SPREAD 20 ON CORE MATERIAL AND MEET SMOKE DEVELOPMENT OF 300. COMPLETE ASSEMBLY TO BE U.L. LISTED, MEET STANDARD BUILDING CODE, UNIFORM BUILDING CODE OR B.O.C.A. AS APPLICABLE FOR FOAMED IN PLACE INSULATED PANELS.

IF THE COOLER OR FREEZER ASSEMBLY HAS AN AGGREGATED FLOOR AREA THAT EXCEEDS 400 SQUARE FEET AND IS WITHIN A BUILDING, THE COOLER OR FREEZER ASSEMBLY MUST BE PROTECTED BY BUILDING AUTOMATIC SPRINKLER SYSTEM.

WHEN QUARRY TILE FLOORING IS PROVIDED IN THE FOOD SERVICE AREAS AND INSIDE THE COOLER AND FREEZER ASSEMBLIES, THE GENERAL CONTRACTOR SHALL PROTECT ALL EXPOSED FOODSERVICE EQUIPMENT METAL SURFACES, DURING GROUTING AND A C/D WASHING OF FLOORING. GENERAL CONTRACTOR TO PROVIDE POWER VENTILATION TO REMOVE FUMES FROM ALL FOODSERVICE AREAS, RESULTING DAMAGE TO STAINLESS STEEL AS A RESULT OF ACID DAMAGE IS UNREPAIRABLE AS ACID WASH FUMES CHANGE THE METAL COMPOSITION OF STAINLESS STEEL. GENERAL CONTRACTOR WILL BE RESPONSIBLE TO REPLACE ALL ACID DAMAGED FOODSERVICE EQUIPMENT AND COOLER/FREEZER PANELS.

SCHEDULE OF EQUIPMENT KITCHEN/SERVERY

ITEM	DESCRIPTION	REMARKS
1	AIR CURTAIN	-
2	18" DRY STORAGE SHELVING	-
3	CAN RACK	NKEC
4	24" DRY STORAGE SHELVING	-
5	WALK-IN COOLER	-
6	24" COOLER SHELVING	-
7	BLOWER COIL +34"	REMOTE
8	SPARE NUMBER	-
9	WALK-IN FREEZER	-
10	24" FREEZER SHELVING	-
11	BLOWER COIL -10"	REMOTE
12	SPARE NUMBER	-
13	SPARE NUMBER	-
14	SPARE NUMBER	-
15	HAND SINK	-
16	REFRIGERATOR	NKEC
17	VEGETABLE PREP SINK	-
18	WALL MOUNTED UTENSIL RACK	-
19	MOBILE TRASH RECEPTACLE	-
20	REFRIGERATOR	NKEC
21	24" CLEAN UTENSIL SHELVING	-
22	MOBILE UTILITY CART	NKEC
23	UTENSIL WASH SINK	-
24	SPARE NUMBER	-
25	SPARE NUMBER	-
26	SPARE NUMBER	-
27	S/S FLOOR TROUGH W/GRATE	-
28	ICE STORAGE BIN	-
29	CUBE ICE MAKER	-
30	WATER FILTRATION SYSTEM	-
31	WORKTABLE	NKEC
32	BAKER'S TABLE	-
33	MOBILE PAN RACK	NKEC
34	SPARE NUMBER	-
35	SPARE NUMBER	-
36	EXHAUST VENTILATOR	-
37	UTILITY DISTRIBUTION SYSTEM	-
38	FIRE SUPPRESSION SYSTEM	-
39	FIRE PULL BOX	-
40	EMERGENCY KILL SWITCH	-
41	DOUBLE CONVECTION OVEN	-
42	S/S FLOOR TROUGH W/GRATE	-
43	40 GALLON TILTING KETTLE	-
44	SPARE NUMBER	-
45	S/S FLOOR TROUGH W/GRATE	-
46	40 GALLON TILTING KETTLE	-
47	STEMMERS/MICROWAVE W/STAND	FUTURE
48	DOUBLE CONVECTION OVEN	-
49	CLASS K FIRE EXTINGUISHER	NKEC
50	SPARE NUMBER	-
51	SPARE NUMBER	-
52	COOK'S TABLE W/SINK	-
53	MOBILE EQUIPMENT STAND	NKEC
54	FOOD CHOPPER	NKEC
55	SPARE NUMBER	-
56	SPARE NUMBER	-
57	SPARE NUMBER	-
58	SPARE NUMBER	-
59	ROLL-THRU HEATED CABINET	-
60	ROLL-THRU REFRIGERATOR	AIR-COOLED
61	SPARE NUMBER	-
62	SPARE NUMBER	-
63	HOT FOOD SERVING COUNTER	-
64	REFRIGERATED DISPLAY	-
65	COLD FOOD SERVING COUNTER	-
66	SPARE NUMBER	-
67	SPARE NUMBER	-
68	SPARE NUMBER	-
69	ESPRESSO SYSTEM	NKEC
70	CASHER COUNTER	-
71	HOT FOOD SERVING COUNTER	-
72	SPARE NUMBER	-
73	SPARE NUMBER	-
74	WOP SINK	NKEC
75	WALL MOUNTED HOSE REEL	-
76	UTILITY FAUCET	-
77	WASHER	-
78	DRYER	-
79	SPARE NUMBER	-
80	LOCKERS	-
81	SPARE NUMBER	-
82	REMOTE CONDENSING UNIT +34"	AIR-COOLED
83	REMOTE CONDENSING UNIT +34"	AIR-COOLED

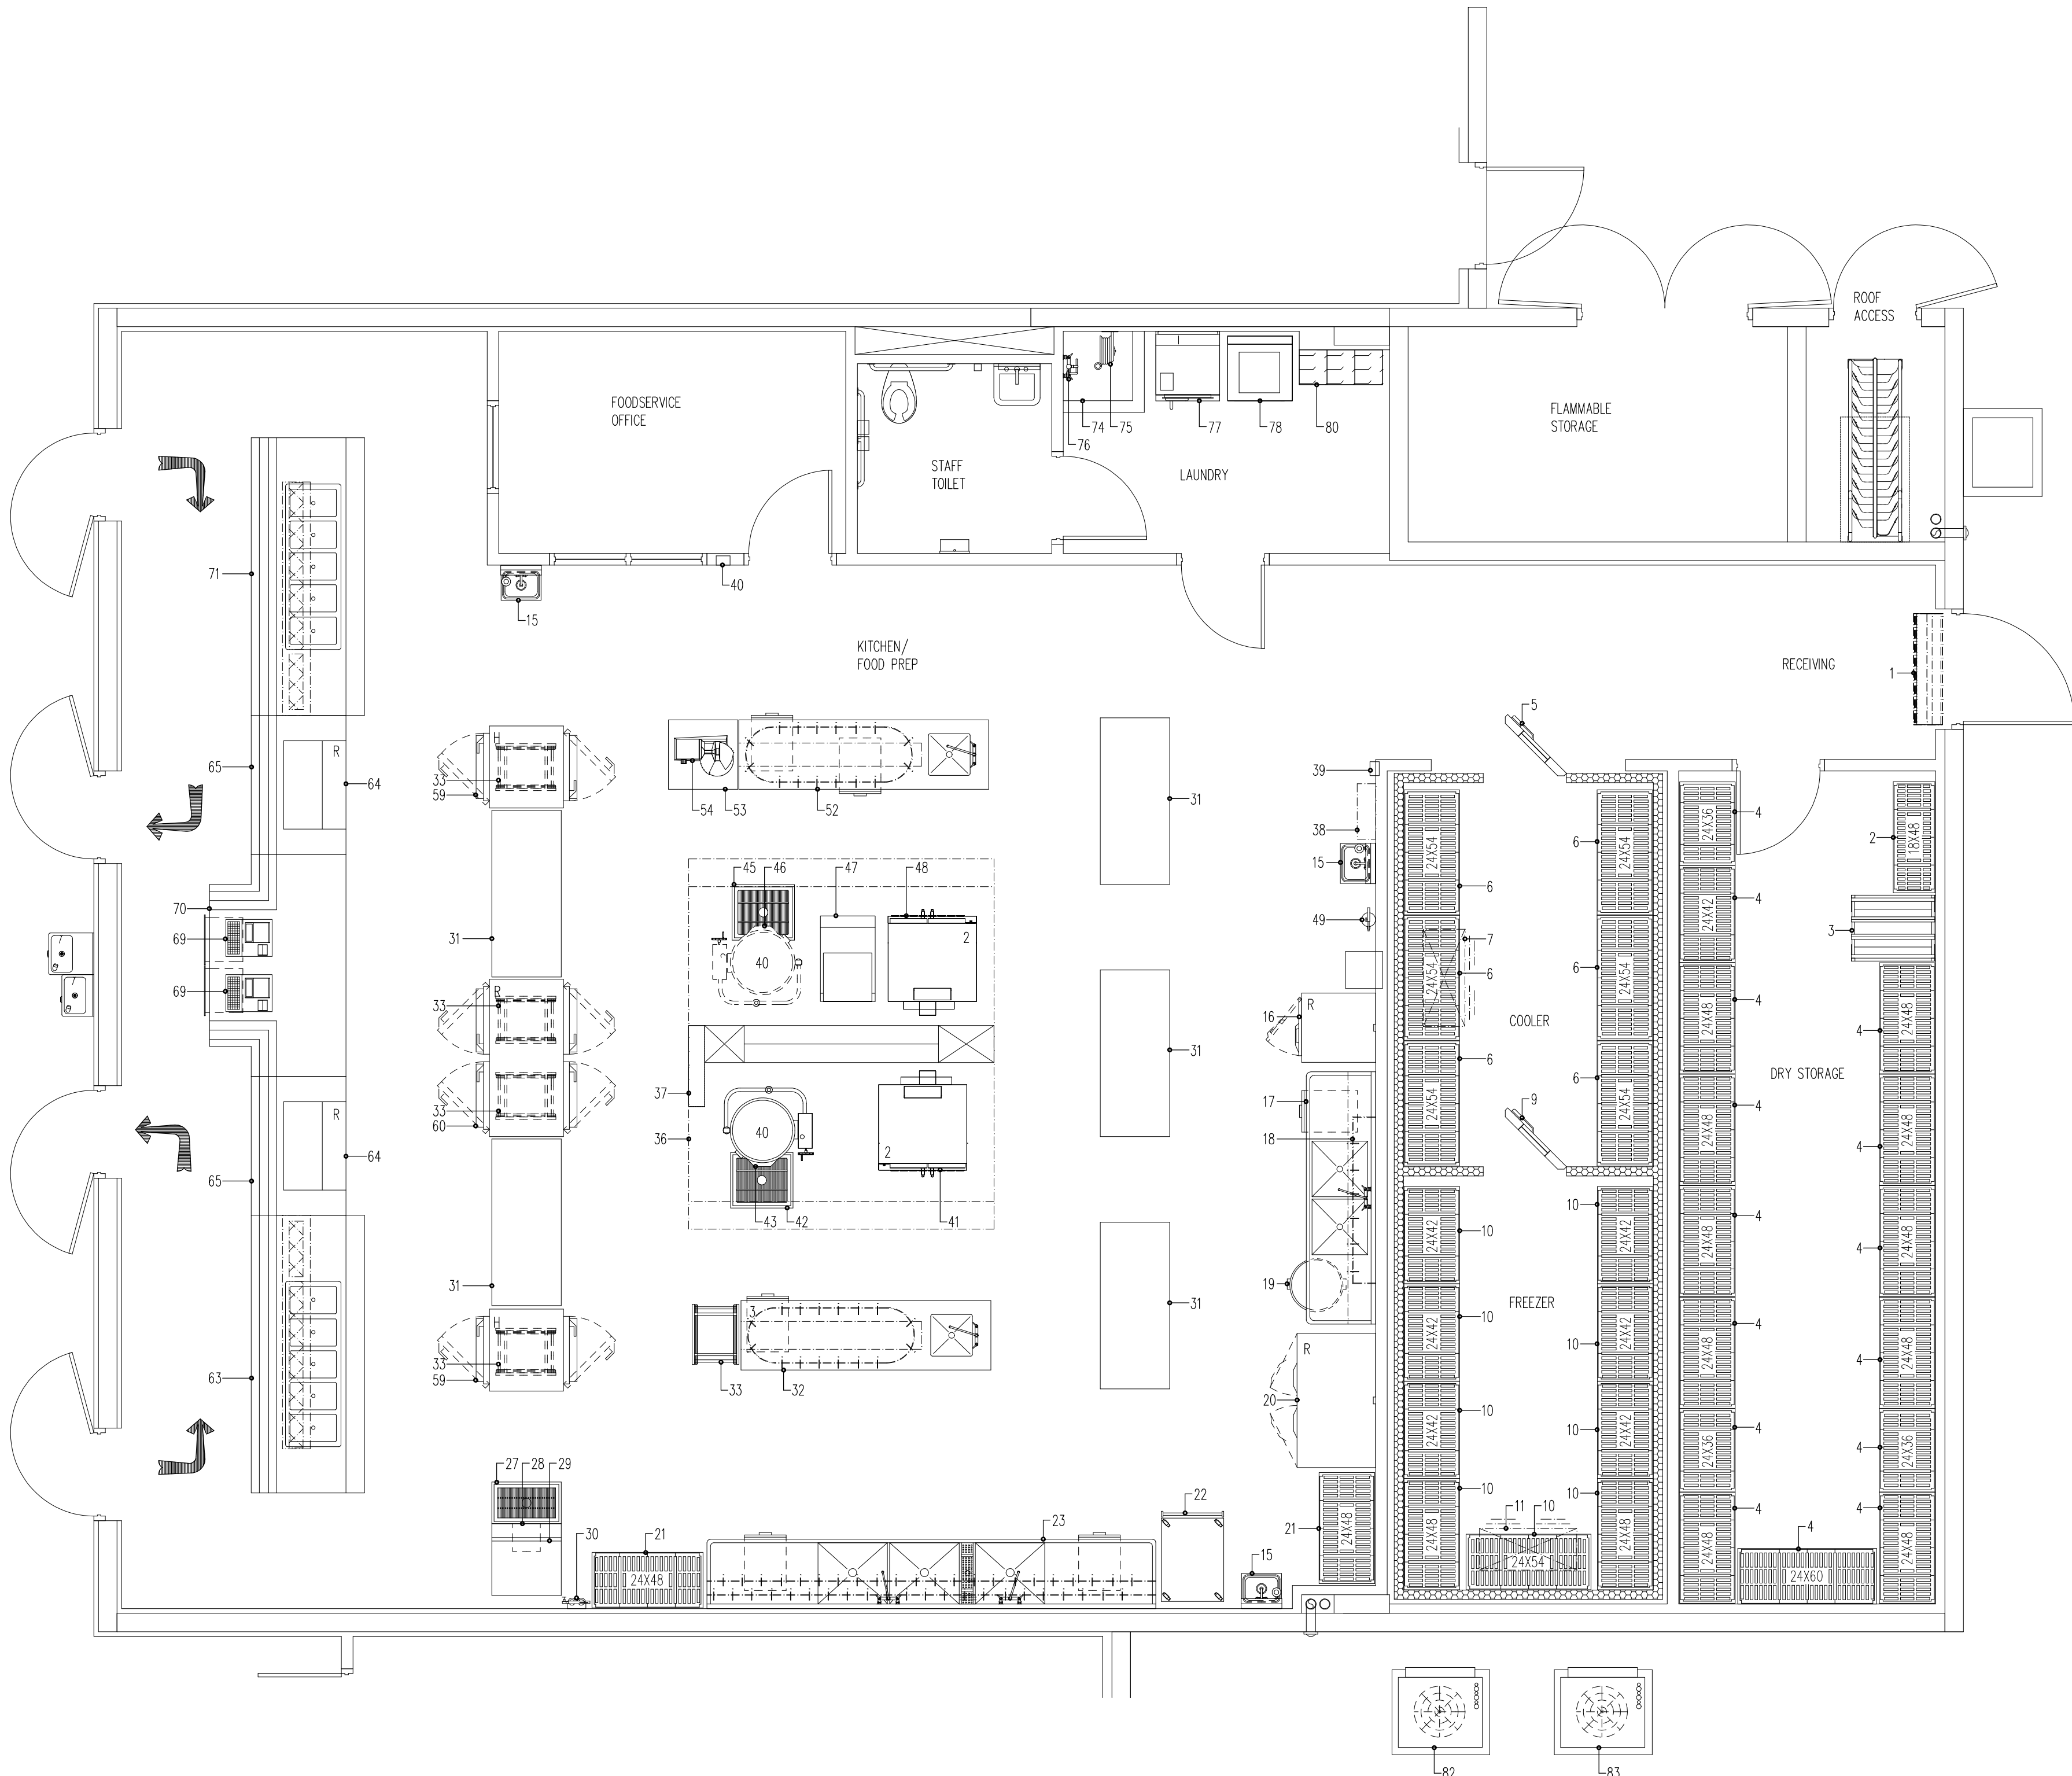

SHEET INDEX

FS-1.1		KITCHEN & SERVERY EQUIPMENT PLAN
FS-1.2		KITCHEN & SERVERY PLUMBING PLAN
FS-1.3		KITCHEN & SERVERY ELECTRICAL PLAN
FS-1.4		KITCHEN & SERVERY SPECIAL CONDITIONS PLAN
FS-1.5		KITCHEN & SERVERY REFRIGERATION PLAN

ALL DRAWINGS WRITTEN SPECIFICATIONS AND DETAILS APPEARING HEREIN CONSTITUTE THE ORIGINAL AND UNPUBLISHED WORK OF INMAN FOODSERVICES GROUP - LLC, AND MAY NOT BE DUPLICATED, USED, OR DISCLOSED WITHOUT THE EXPRESS WRITTEN CONSENT OF INMAN FOODSERVICES GROUP - LLC.

CONSULTANT INFO:



• NASHVILLE
• MIAMI
• SAN ANTONIO


NEW ELEMENTARY SCHOOL (K-5)

VENETIAN PARC WEST

SOUTHWEST 157th AVENUE and 174th STREET
MIAMI, FL. 33187

MDCPS PROJECT No. 01892600

KEY PLAN

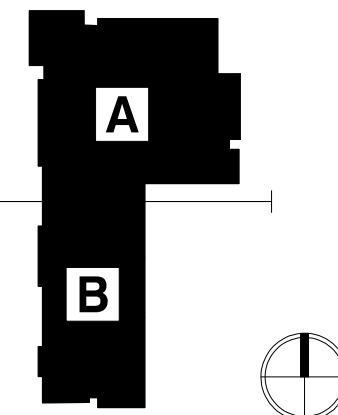

CONSULTANT INFO:



MODEL & REVISIONS TABLE
FLOOR 1: 10/10/2019
FLOOR 2: 10/10/2019
FLOOR 3: 10/10/2019
FLOOR 395: 10/10/2019
FLOOR 396: 1

PLUMBING NOTES

ALL DIMENSIONS SHOWN ARE FROM FINISHED WALLS, FLOORS, CEILINGS AND/OR FROM CENTERLINE OF STRUCTURAL COLUMNS. DIMENSIONS ARE TO BE VERIFIED BY THE KITCHEN EQUIPMENT CONTRACTOR AND ALL TRADES UTILIZING THESE PLANS.

ANY "HOLD" DIMENSIONS ARE CLEAR "FINISH-TO-FINISH" UNLESS OTHERWISE NOTED.

UTILITIES SHOWN ARE FOR ITEMS OF FOODSERVICE EQUIPMENT ONLY AND ARE THE MINIMUM REQUIRED TO OPERATE EQUIPMENT. LOCATIONS OF ANY ADDITIONAL PLUMBING UTILITIES WHICH MAY BE REQUIRED SHALL BE DETERMINED BY THE ARCHITECT/ENGINEER.

PLUMBING PLAN SHOWS OUTLET AND CONNECTION LOCATIONS WITH CAPACITIES. FOR ACTUAL ROUGH-IN LOCATIONS, REFER TO DIMENSIONED DRAWINGS FURNISHED BY KITCHEN EQUIPMENT CONTRACTOR.

FINAL PLUMBING CONNECTIONS INCLUDING MOUNTING OF DRAINS, FAUCETS AND PIPING FROM POINT-OF-CONNECTION ON EQUIPMENT TO BUILDING PLUMBING SYSTEM AND INTERCONNECTIONS BETWEEN EQUIPMENT COMPONENTS SHALL BE PROVIDED BY PLUMBING CONTRACTOR.

PLUMBING CONTRACTOR SHALL PROVIDE FINAL INTERCONNECTION BETWEEN EQUIPMENT AND UTILITY DISTRIBUTION SYSTEM. QUICK DISCONNECT HOSES SHALL BE FURNISHED LOOSE BY THE KITCHEN EQUIPMENT CONTRACTOR.

ALL PLUMBING MATERIALS, INCLUDING PIPE, TRAPS, STOPS, VALVES, FITTINGS, SHUT-OFFS, WATER HAMMER ARRESTORS, PRESSURE REDUCING VALVES, GAUGES, UNIONS AND INSULATION SHALL BE PROVIDED BY PLUMBING CONTRACTOR.

PLUMBING CONTRACTOR SHALL INSTALL ALL FAUCETS AND PLUMBING ACCESSORIES PROVIDED LOOSE BY KITCHEN EQUIPMENT CONTRACTOR.

UTILITIES (GAS, WATER, STEAM) SHALL BE CONCEALED IN WALLS AND STUBBED-OUT OF FINISHED WALLS 6" PIPING STUBBED OUT OF THE FLOOR OR WALL AND RUN EXPOSED SHALL NOT BE ACCEPTABLE AND IS IN VIOLATION OF HEALTH DEPARTMENT CODES. ALL PENETRATIONS SHALL BE SEALED IN WATER TIGHT.

ALL EXPOSED PIPING SHALL BE CHROME PLATED TO SATISFY LOCAL HEALTH DEPARTMENT.

PLUMBING COMPONENTS, PROVIDED BY PLUMBING CONTRACTOR INCLUDING VALVES, TRAPS, SHUT-OFFS, GAUGES AND CONNECTIONS SHALL NOT INTERFERE IN ANY WAY WITH THE OPERATION OF ITEMS OF FOODSERVICE EQUIPMENT.

WATER PRESSURE IN EQUIPMENT AREA SHOULD NOT EXCEED 50 PSI IN BOTH HOT AND COLD WATER SUPPLY LINES. THE WATER PRESSURE TO DISHWASHERS, GLASSWASHERS AND BOOSTER HEATERS SHOULD NOT EXCEED 25 PSI. PRESSURE REDUCING VALVES PROVIDED BY PLUMBING CONTRACTOR MUST MEET EQUIPMENT MANUFACTURER'S FLOW RECOMMENDATIONS.

FLOOR SINKS SHALL BE INSTALLED FLUSH WITH FINISHED FLOOR WITH OR WITHOUT GRATE COVER AS INDICATED ON PLAN.

ALL LINES SHALL BE FLUSHED FREE OF FOREIGN MATTER AND LINE STRAINERS AND FAUCET AERATORS CLEANED PRIOR TO MAKE-UP OF FINAL UTILITY CONNECTIONS BY PLUMBING CONTRACTOR.

GREASE TRAPS SHALL BE PROVIDED BY PLUMBING CONTRACTOR AND SHALL BE RECESS-MOUNTED, FLUSH WITH TOP OF FINISHED FLOOR. GREASE TRAPS SHALL NOT BE LOCATED BENEATH ANY ITEM OF FOODSERVICE EQUIPMENT AND THE REMOVAL OF COVER SHALL NOT INTERFERE WITH THE OPERATION OF ANY FOODSERVICE EQUIPMENT ITEMS.

DRAIN LINES FROM EVAPORATOR COILS (QUICK-FALL TYPE) SHALL BE TRAPPED OUTSIDE OF WALK-IN FREEZER/COOLER ASSEMBLIES AND EXTENDED OVER BUILDING DRAIN BY PLUMBING CONTRACTOR. ALL PENETRATIONS IN WALK-IN FREEZER/COOLER ASSEMBLIES SHALL BE MADE BY KITCHEN EQUIPMENT CONTRACTOR. REFER TO EVAPORATOR COIL DETAIL.

TRENCH-TYPE DRAIN TROUGH SHALL BE FURNISHED BY THE KITCHEN EQUIPMENT CONTRACTOR TO THE GENERAL CONTRACTOR FOR INSTALLATION. PLUMBING CONTRACTOR SHALL PROVIDE DRAIN CONNECTIONS AS SHOWN ON DETAILS.

GAS MAIN SHALL BE PROVIDED WITH A READILY ACCESSIBLE MANUAL SHUT-OFF VALVE BY PLUMBING CONTRACTOR. LOCATION OF VALVE TO BE COORDINATED WITH FOOD-SERVICE CONSULTANT. A LOOPED GAS SERVICE IS RECOMMENDED TO PROVIDE FOR BALANCED FUEL DISTRIBUTION. SIZE OF GAS LINE TO BE DETERMINED BY ARCHITECT/ENGINEER. SEE PLUMBING SCHEDULE FOR BTU/HOUR REQUIREMENTS.

PLUMBING CONTRACTOR SHALL PROVIDE MANUAL GAS SHUT-OFF DEVICES AT EACH INDIVIDUAL PIECE OF EQUIPMENT NOT BATTERED TOGETHER. LOCATION OF FUEL SHUT-OFF VALVES TO BE COORDINATED WITH FOODSERVICE CONSULTANT. GAS PRESSURE REDUCING VALVES REQUIRED FOR EACH INDIVIDUAL PIECE OF COOKING EQUIPMENT SHALL BE FURNISHED BY KITCHEN EQUIPMENT CONTRACTOR FOR INSTALLATION BY PLUMBING CONTRACTOR.

FOR VENTILATION FIRE SUPPRESSION SYSTEM WITH GAS HEATED COOKING EQUIPMENT, PLUMBING CONTRACTOR SHALL INSTALL MECHANICAL FUEL SHUT-OFF VALVE FURNISHED BY KITCHEN EQUIPMENT CONTRACTOR IN GAS LINES SERVING COOKING EQUIPMENT. LOCATION OF FUEL SHUT-OFF VALVES TO BE COORDINATED WITH FOODSERVICE CONSULTANT. KITCHEN EQUIPMENT CONTRACTOR SHALL PROVIDE REMOTE MANUAL PULL STATION AND MICRO-SWITCH. GAS SHUT-OFF VALVE SHALL BE MECHANICALLY ACTIVATED IN CASE OF FIRE BY MECHANICAL/PNEUMATIC MECHANISM. ANY AND ALL ELECTRICAL INTERCONNECTING REQUIRED FOR FAN CONTROL AND/OR ALARM SYSTEMS SHALL BE BY ELECTRICAL CONTRACTOR.

PLUMBING CONNECTIONS SCHEDULE


NUMBER	SIZE	DESCRIPTION	LOCATION	A.F.F.	SERVICES TO	ITEM NO.	REMARKS
P1	1"	INDIRECT WASTE	-	-	AIR GAP DRAIN	-	-
P2	2"	INDIRECT WASTE	-	-	AIR GAP DRAIN	-	-
P3	1/2"	HOT & COLD WATER	WALL	18"	FAUCET	-	P.C. TO BRANCH TO CONNECTION AS REQUIRED
P4	1/2"	HOT & COLD WATER	WALL	12"/24"	HAND SINK	-	P.C. TO BRANCH TO CONNECTION AS REQUIRED
P5	1-1/2"	DIRECT WASTE	WALL	-	HAND SINK	-	P.C. TO DETERMINE DRAIN HEIGHT
P6	FLOOR SINK	-	-	-	-	-	-
P7	FLOOR DRAIN	-	-	-	-	-	-
P8	FUNNEL FLOOR DRAIN	-	-	-	-	-	-
P9	3/4"	HOT & COLD WATER	WALL	18"	UTENSIL WASH SINK	23	P.C. TO BRANCH TO CONNECTION AS REQUIRED
P10	4"	DIRECT WASTE	FLOOR	-	FLOOR TROUGH	27	-
P11	1/2"	COLD WATER	WALL	76"	WATER FILTRATION SYSTEM	30	P.C. TO CONNECT TO CUBE ICE MAKER THRU WATER FILTRATION SYSTEM
P12	1/2"	HOT & COLD WATER	FLOOR	STUB	FAUCET	-	P.C. TO BRANCH TO CONNECTION AS REQUIRED
P13	3/4"	HOT WATER	FA	CLG	UTILITY DISTRIBUTION SYSTEM	37	P.C. TO BRANCH TO CONNECTION AS REQUIRED
P14	3/4"	COLD WATER	FA	CLG	UTILITY DISTRIBUTION SYSTEM	37	P.C. TO BRANCH TO CONNECTION AS REQUIRED
P15	1"	HOT WATER @ 140° F. MIN.	FA	CLG	UTILITY DISTRIBUTION SYSTEM	37	P.C. TO BRANCH TO CONNECTION AS REQUIRED
P16	1"	INDIRECT WASTE	-	-	UTILITY DISTRIBUTION SYSTEM	37	P.C. TO BRANCH TO CONNECTION AS REQUIRED
P17	3"	INDIRECT WASTE	-	-	UTILITY DISTRIBUTION SYSTEM	37	P.C. TO BRANCH TO CONNECTION AS REQUIRED
P18	3"	DIRECT WASTE	FLOOR	-	FLOOR TROUGH	42	-
P19	3"	DIRECT WASTE	FLOOR	-	FLOOR TROUGH	45	-
P20	1/2"	COLD WATER	FLOOR	STUB	SUPPLY	-	P.C. TO BRANCH TO CONNECTION AS REQUIRED
P21	4"	DIRECT WASTE	FLOOR	-	MOP SINK	74	-
P22	1/2"	HOT & COLD WATER	WALL	36"	HOSE REEL	75	P.C. TO BRANCH TO CONNECTION AS REQUIRED
P23	1/2"	HOT & COLD WATER	WALL	36"	UTILITY FAUCET	76	P.C. TO BRANCH TO CONNECTION AS REQUIRED
P24	1/2"	HOT & COLD WATER	WALL	48"	WASHER	77	P.C. TO BRANCH TO CONNECTION AS REQUIRED
P25	1-1/2"	STAND PIPE	WALL	48"	WASHER	77	-

NOTE:
DRAIN LOCATIONS SHOWN ARE TO A DEGREE ARBITRARY, THEREFORE, SHOULD LOCATIONS CONFLICT WITH STRUCTURAL ELEMENTS OR OTHER UTILITY SYSTEMS, SOME MOVEMENT OF THE ROUGH-IN POINT IS POSSIBLE. ALWAYS MAKE THE DRAIN MORE ACCESSIBLE RATHER THAN OBSCURED BY EQUIPMENT. SOME AREA FLOOR DRAINS MAY BE RELOCATED TO FACILITATE ECONOMY OF DESIGN.

NOTE:
AREA FLOOR DRAINS ARE TO BE PROVIDED AND LOCATED BY THE PLUMBING CONTRACTOR. LOCATIONS SHOWN ON PLAN ARE WITHIN CLOSE PROXIMITY OF DESIRED LOCATION. PLUMBING CONTRACTOR TO TRY TO INCORPORATE FLOOR DRAINS AS CLOSE AS POSSIBLE, PER FIELD CONDITIONS.

PLUMBING SYMBOLS

COLD WATER	CW	●
HOT WATER	HW	●
WASTE	W	●
INDIRECT WASTE	IW	○
FLOOR DRAIN	FD	⊗
FUNNEL-TYPE FLOOR DRAIN	FFD	⊗
FLOOR SINK - 1/2 GRATE	FS	⊗
POINT OF CONNECTION ON EQUIPMENT		○

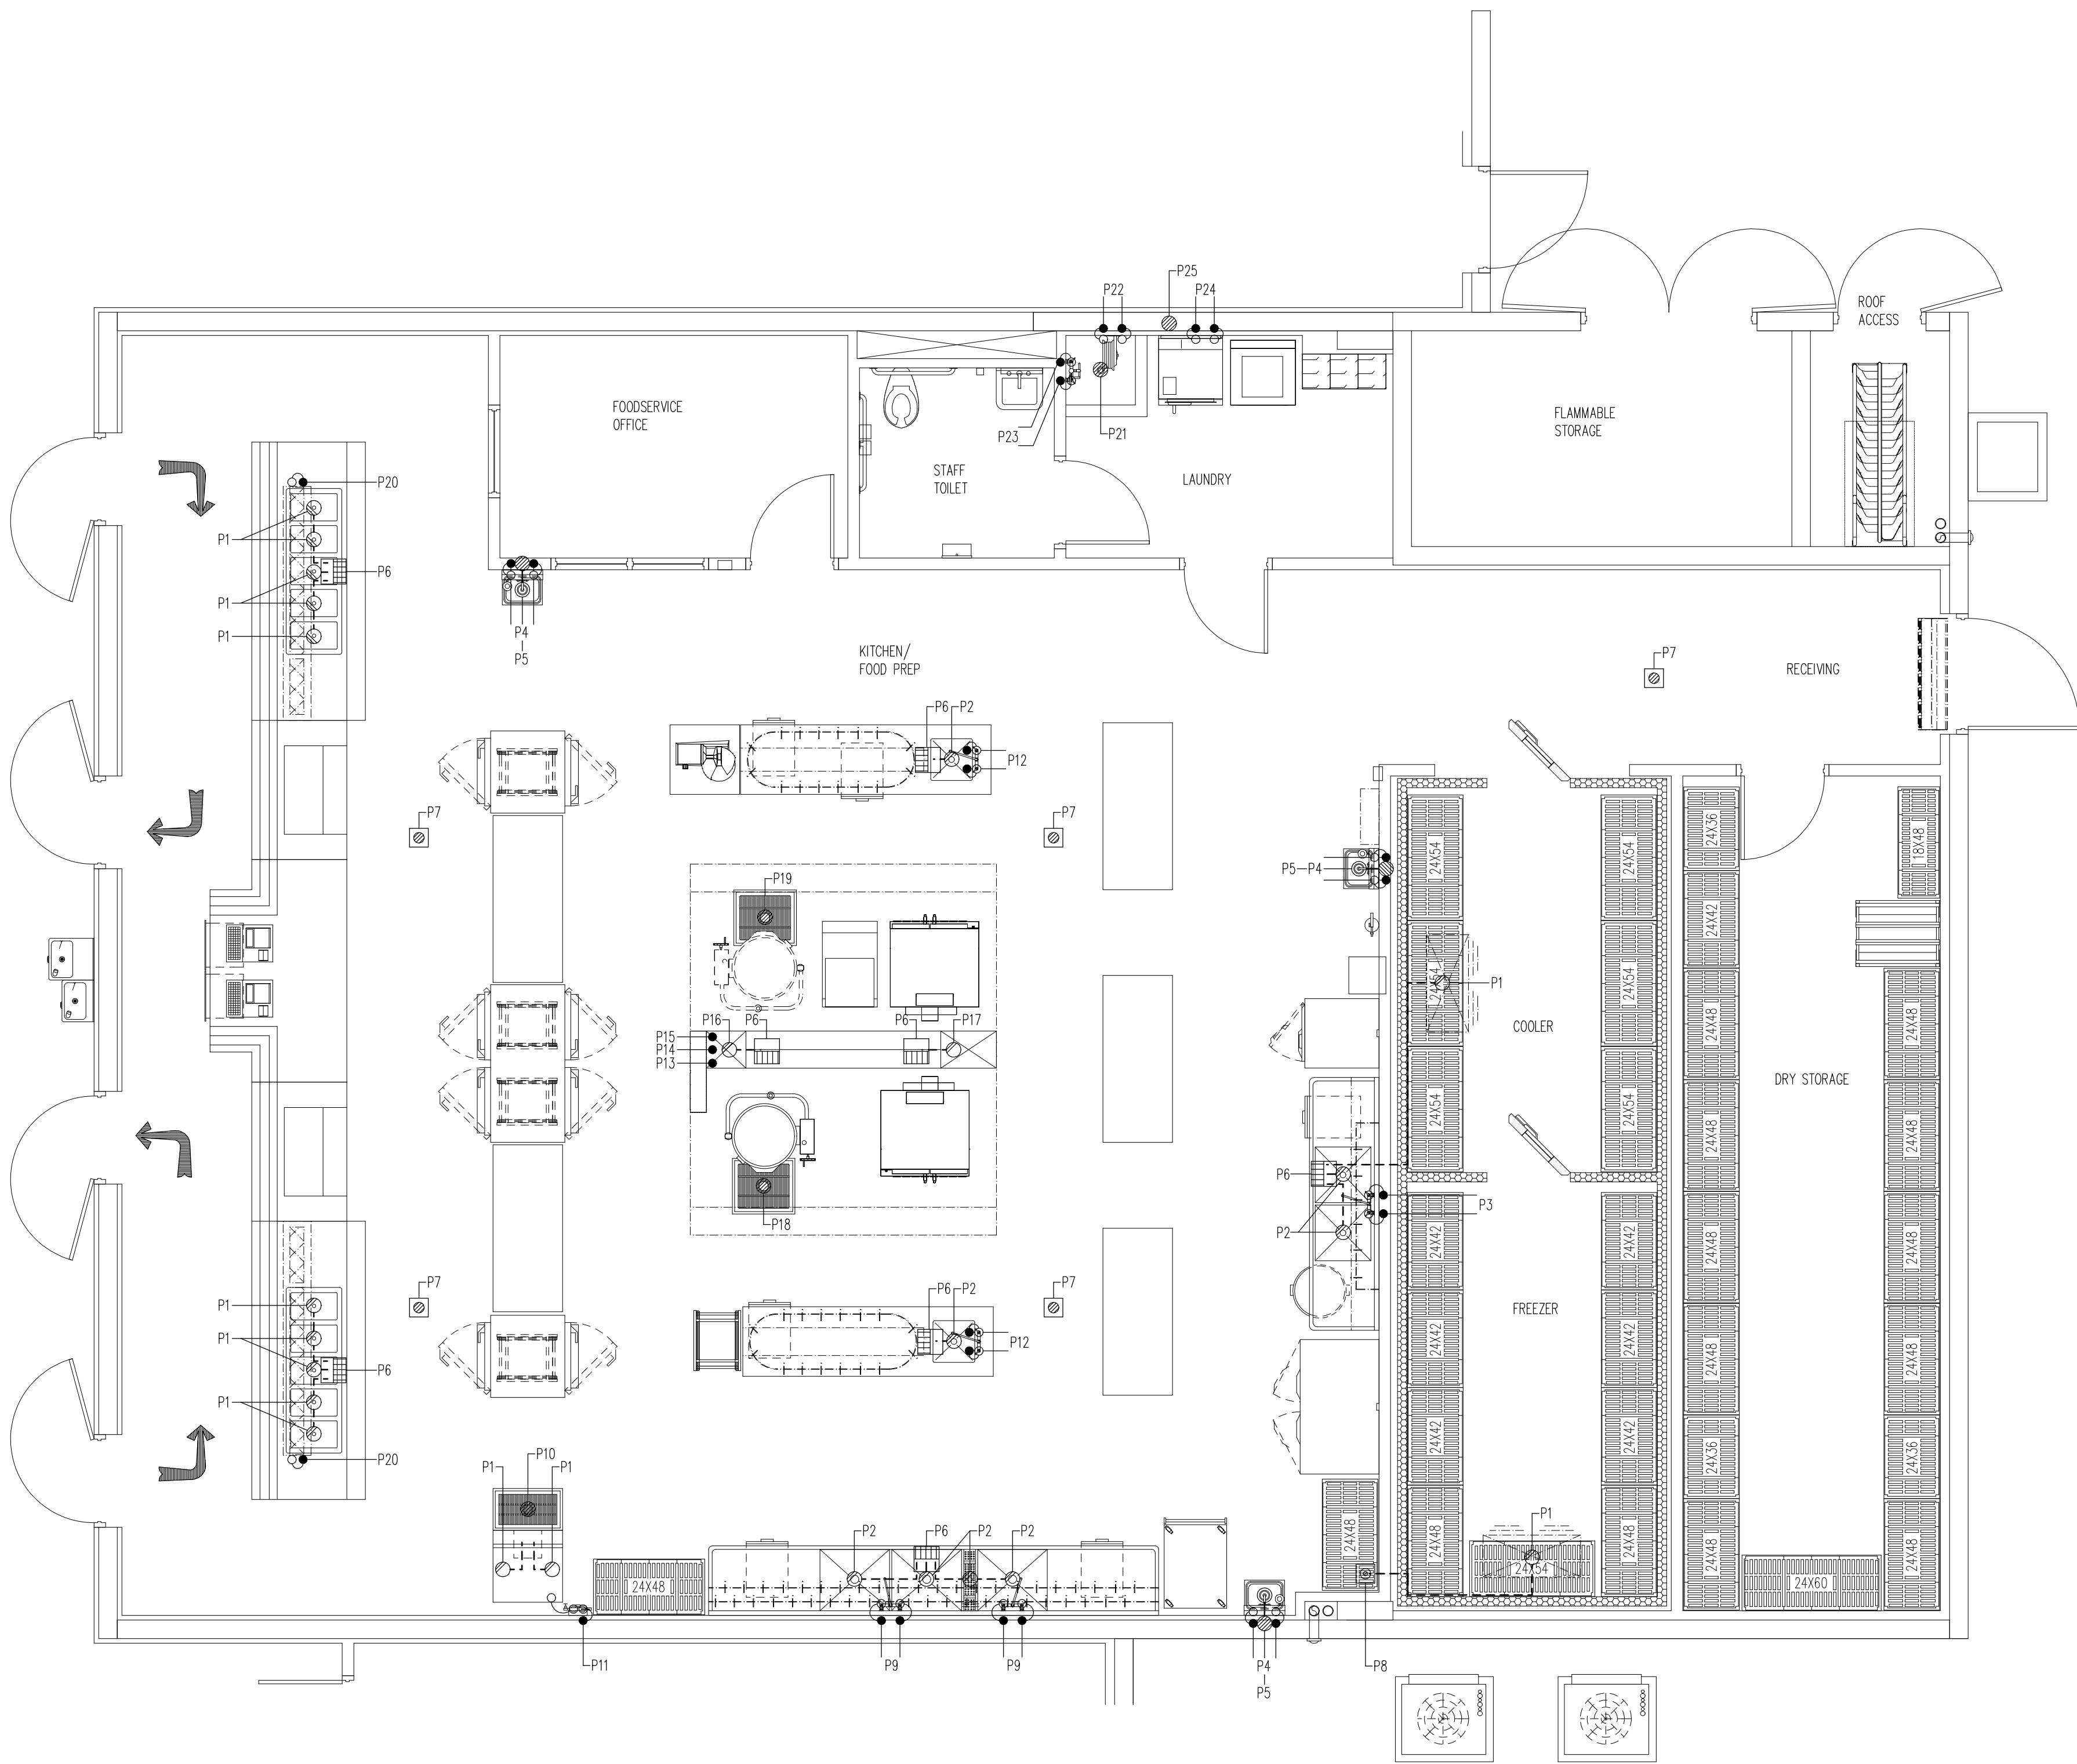


ALL DRAWINGS WRITTEN SPECIFICATIONS AND DETAILS APPEARING HEREIN CONSTITUTE THE ORIGINAL AND UNPUBLISHED WORK OF INMAN FOODSERVICES GROUP - LLC, AND MAY NOT BE DUPLICATED, USED, OR DISCLOSED WITHOUT THE EXPRESS WRITTEN CONSENT OF INMAN FOODSERVICES GROUP - LLC.

NEW ELEMENTARY SCHOOL (K-5)
VENETIAN PARC WEST

SOUTHWEST 157th AVENUE and 174th STREET
MIAMI, FL. 33187
MDCPS PROJECT No. 01892600


KEY PLAN

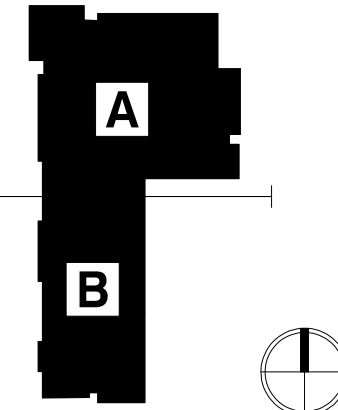


CONSULTANT INFO:



PROJECT: A. RODRIGUEZ, P.E.
FLOOR: B. RODRIGUEZ, P.E.
FLOOR: C. RODRIGUEZ, P.E.
FLOOR: D. RODRIGUEZ, P.E.

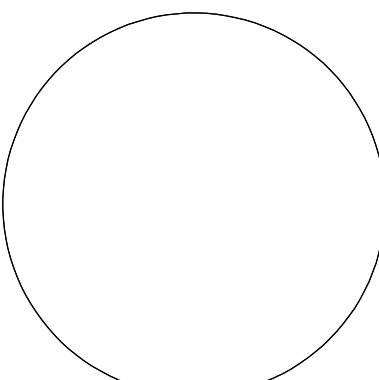

RODRIGUEZ
ARCHITECTS
INCORPORATED
2121 PONCE DE LEON BLVD. STE.
1010 CORAL GABLES, FL. 33134
TEL: (305) 448-3373
FAX: (305) 448-3374

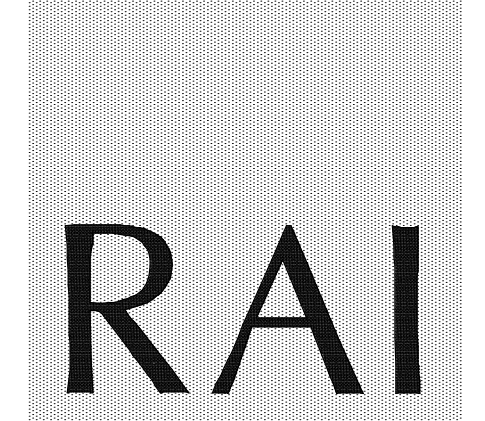

REVISIONS:

1	
2	
3	
4	
5	
6	
7	

DRAWING TITLE:
PLUMBING PLAN
AND SCHEDULE
SCALE: 1/4" = 1'-0"
ISSUE DATE:
12.16.19
PROJECT NO:
1906
SHEET:
FS-1.2

ELECTRICAL NOTES

ELECTRICAL SYSTEM IS DESIGNED FOR 120/208 VOLT, 3 PHASE, 60 HERTZ SYSTEM.

ALL DIMENSIONS SHOWN ARE FROM FINISHED WALLS, FLOORS, CEILINGS AND/OR FROM CENTERLINE OF STRUCTURAL COLUMNS. DIMENSIONS ARE TO BE VERIFIED BY THE KITCHEN EQUIPMENT CONTRACTOR AND ALL TRADES UTILIZING THESE PLANS.

ANY "HOLD" DIMENSIONS ARE CLEAR "FINISH-TO-FINISH" UNLESS OTHERWISE NOTED.

UTILITIES SHOWN ARE FOR ITEMS FOR FOOD SERVICE EQUIPMENT ONLY AND ARE THE MINIMUM REQUIRED TO OPERATE EQUIPMENT. LOCATIONS OF ANY ADDITIONAL ELECTRICAL UTILITIES (CONVENIENCE RECEPTACLES, TELEPHONE JACKS, INTERCOM JACKS, ETC.) WHICH MAY BE REQUIRED SHALL BE DETERMINED BY THE ARCHITECT/ENGINEER.

ELECTRICAL PLAN SHOWS OUTLETS AND CONNECTION WITH CAPACITIES. FOR ACTUAL ROUGH-IN LOCATIONS, REFER TO DIMENSIONED DRAWINGS PROVIDED BY KITCHEN EQUIPMENT CONTRACTOR.

FINAL ELECTRICAL CONNECTIONS INCLUDING WIRING FROM POINT-OF CONNECTION ON EQUIPMENT TO BUILDING ELECTRICAL SYSTEM AND INTERCONNECTIONS BETWEEN EQUIPMENT COMPONENTS SHALL BE PROVIDED BY ELECTRICAL CONTRACTOR.

ALL ELECTRICAL MATERIALS, INCLUDING WIRE, CONDUIT, OVERLOAD PROTECTION, MAIN SWITCHES, SAFETY OUT-OUTS, FUSE BOXES, SHUNT-STRIP BREAKERS, DISCONNECT SWITCHES AND CONTROLS SHALL BE PROVIDED BY ELECTRICAL CONTRACTOR.

UTILITIES SHALL BE CONCEALED IN WALLS AND STUBBED-OUT OF WALLS. WIRING STUBBED OUT OF FLOOR AND RUN EXPOSED ON THE FACE OF THE WALL SHALL NOT BE ACCEPTABLE.

ELECTRICAL COMPONENTS, INCLUDING MAIN SWITCHES, FUSE BOXES, TERMINAL PANELS, DISCONNECT SWITCHES CONDUIT AND CONNECTIONS SHALL NOT INTERFERE IN ANY WAY WITH THE OPERATION OF ITEMS OF FOODSERVICE EQUIPMENT.

AMPERAGES INDICATED ARE TOTAL FOR EACH UNIT AND NOT IN ADDITION TO ANY HP AND/OR KW RATINGS SHOWN.

WHERE CALLED FOR, KITCHEN EQUIPMENT CONTRACTOR SHALL FURNISH CORDS AND PLUGS FOR INSTALLATION BY ELECTRICAL CONTRACTOR. NEMA NUMBERS SHOWN INDICATE THE CORD CONFIGURATION TO BE PROVIDED FOR THE EQUIPMENT. ANY DIRECT CONNECTIONS SHALL BE PROVIDED BY ELECTRICAL CONTRACTOR.

ALL LIGHT FIXTURES IN FOOD STORAGE, PREPARATION, SERVICE OR DISPLAY FACILITIES, AS WELL AS UTENSIL CLEANING AND STORAGE AREAS SHALL HAVE SHIELDING OVER BULBS.

KITCHEN EQUIPMENT CONTRACTOR SHALL PROVIDE WALK-IN FREEZER/COOLER ASSEMBLIES COMPLETE WITH OUTLET BOXES, DOOR HEATERS AND ALL SYSTEM COMPONENTS PRE-WIRED TO A SINGLE POINT OF CONNECTION. ELECTRICAL CONTRACTOR SHALL PROVIDE INTERCONNECTING CONDUIT AND WIRING AND MAKE FINAL CONNECTIONS.

ELECTRICAL CONTRACTOR SHALL PROVIDE ELECTRICAL POWER TO AND INTERCONNECTION BETWEEN EVAPORATOR COIL, TIME CLOCK, TEMPERATURE CONTROL DEVICE, AND CONDENSING UNITS, FOR WALK-IN FREEZER/COOLER ASSEMBLIES FURNISHED BY KITCHEN EQUIPMENT CONTRACTOR.

DRAIN LINE FROM FREEZER COIL SHALL BE WRAPPED WITH HEAT CABLE, TAPED AND INSULATED TO PREVENT FREEZING OF CONDENSATE IN THE LINE, BY ELECTRICAL CONTRACTOR.

WALK-IN FREEZER/COOLER VAPOR-PROOF LIGHT FIXTURES ARE SHIPPED LOOSE BY KITCHEN EQUIPMENT CONTRACTOR FOR FIELD INSTALLATION AND INTERWIRING AS REQUIRED BY ELECTRICAL CONTRACTOR.

ALL PENETRATIONS INTO WALK-IN FREEZER/COOLERS SHALL BE MADE BY KITCHEN EQUIPMENT CONTRACTOR.

ELECTRICAL CONTRACTOR SHALL SEAL ALL PENETRATIONS MADE INTO WALK-IN FREEZER/COOLER ASSEMBLIES, REFRIGERATORS AND EXHAUST VENTILATORS WITH METHODS AND MATERIALS AS APPROVED BY EQUIPMENT MANUFACTURER.

KITCHEN EQUIPMENT CONTRACTOR SHALL PROVIDE EXHAUST VENTILATOR ASSEMBLIES COMPLETE WITH: CONTROL PANEL, WASH-DOWN PANEL, LIGHTS, AND FIRE SUPPRESSION SYSTEM. ELECTRICAL CONTRACTOR SHALL PROVIDE ALL POWER TO AND INTERCONNECTIONS BETWEEN VENTILATOR, CONTROL PANEL, WASH-DOWN PANEL LIGHTS, EXHAUST AND SUPPLY FAN, WASH-DOWN CHARTERS, AND ALL MISCELLANEOUS COMPONENTS. SEE PLAN AND VENTILATOR SHOP DRAWINGS FOR ADDITIONAL INFORMATION.

FOR VENTILATOR FIRE SUPPRESSION SYSTEM WITH ELECTRICALLY HEATED COOKING EQUIPMENT, KITCHEN EQUIPMENT CONTRACTOR SHALL PROVIDE REMOTE MANUAL PULL STATION, AND MICRO-SWITCH. ELECTRICAL CONTRACTOR SHALL FURNISH AND INSTALL ELECTRICAL CONTRACTORS AND/OR SHUNT TRIP BREAKERS AND ALL INTERCONNECTION CONDUIT AND WIRING FOR SHUT-OFF OF ALL ELECTRICALLY HEATED COOKING EQUIPMENT. CONTRACTOR FOR SHUNT TRIP RELAYS SHALL BE ACTIVATED IN CASE OF FIRE BY MICRO-SWITCH AS FURNISHED BY KITCHEN EQUIPMENT CONTRACTOR.

FIRE PROTECTION SYSTEM REMOTE CABLE PULL BOX SHALL BE RECESS MOUNTED OCTAGONAL J-BOX WITH SCREW HOLES AT 2" AND 8"-0" CLOCK WITH 1/2" EMT CONDUIT OUT OF TOP, CONCEALED IN WALL TO 6" ABOVE FINISHED CEILING, BY ELECTRICAL CONTRACTOR.

ELECTRICAL CONTRACTOR SHALL PROVIDE EMPTY CONDUIT WITH J-BOXES FOR INSTALLATION OF OWNER SUPPLIED CASH REGISTER SYSTEM. VERIFY EXACT REQUIREMENTS WITH EQUIPMENT SUPPLIER.

ELECTRICAL CONTRACTOR SHALL PROVIDE COMPUTER GRADE, ISOLATED GROUND ELECTRICAL SERVICE FOR ELECTRICAL CASH REGISTER EQUIPMENT. VERIFY EXACT REQUIREMENTS WITH EQUIPMENT SUPPLIER.

ELECTRICAL RECEPTACLES SHALL BE INSTALLED WITH THEIR LONG DIMENSION RUN HORIZONTALLY. ALL 120/1 SINGLE AND DOUBLE RECEPTACLES TO BE PROVIDED AS GFI PROTECTED.

ELECTRICAL CONTRACTOR SHALL PROVIDE EMPTY CONDUIT RACKWAY SYSTEM, FOR REMOTE REFRIGERATION LINES AS INDICATED ON REFRIGERATION PLAN AND DETAILS. CONDUIT SHALL HAVE 24" MINIMUM RADIUS BENDS.


ELECTRICAL CONTRACTOR SHALL PROVIDE CONDUIT AND POWER AND CONTROL WIRING BETWEEN REMOTE LOW TEMPERATURE EVAPORATORS AND REMOTE COMPRESSOR RACK. REFER TO DRAWINGS FOR DETAILS.

ELECTRICAL CONNECTIONS SCHEDULE

NUMBER	CONNECTION	SERVICE TO	ITEM NO.	RATING	VOLT	PHASE	LOCATION	A.F.F.	REMARKS
E1	JUNCT. BOX	AIR CURTAIN	1	5.1 A	120	1	FA	CLG	E.C. TO BRANCH TO CONNECTION AS REQUIRED
E2	JUNCT. BOX	LIGHTS	5	5.0 A	120	1	FA	CLG	E.C. TO BRANCH TO CONNECTION AS REQUIRED
E3	JUNCT. BOX	BLOWER COIL	7	2.3 A	120	1	FA	CLG	E.C. TO BRANCH TO CONNECTION AS REQUIRED
E4	JUNCT. BOX	DOOR HEATER/LIGHTS	9	7.5 A	120	1	FA	CLG	E.C. TO BRANCH TO CONNECTION AS REQUIRED
E5	DUPLEX	REFRIGERATOR	16	5.2 A	120	1	WALL	86"	-
E6	DUPLEX	CONVENIENCE OUTLET	-	16.0 A	120	1	WALL	50"	-
E7	DUPLEX	REFRIGERATOR	20	6.9 A	120	1	WALL	86"	-
E8	SINGLE	CUBE ICE MAKER	29	17.8 A	208	1	WALL	76"	E.C. TO BRANCH TO CONNECTION AS REQUIRED
E9	J/DUPLEX	CONVENIENCE OUTLET	-	16.0 A	120	1	FLOOR	STUB	E.C. TO CONNECT TO TABLE MOUNTED DUPLEX
E10	JUNCT. BOX	EXHAUST VENTILATOR	36	10.0 A	120	1	FA	CLG	E.C. TO BRANCH TO CONNECTION AS REQUIRED
E11	JUNCT. BOX	UTILITY DISTRIBUTION SYSTEM	37	300.0 A	120/208	3	FA	CLG	E.C. TO BRANCH TO CONNECTION AS REQUIRED
E12	JUNCT. BOX	UTILITY DISTRIBUTION SYSTEM	37	15.0 A	120	1	FA	CLG	E.C. TO BRANCH TO CONNECTION AS REQUIRED
E13	JUNCT. BOX	FIRE SUPPRESSION SYSTEM	38	20.0 A	120	1	FA	CLG	E.C. TO BRANCH TO CONNECTION AS REQUIRED
E14	J/DUPLEX	FOOD CHOPPER	54	20.0 A	120	1	FLOOR	STUB	E.C. TO CONNECT TO TABLE MOUNTED DUPLEX
E15	DC/SINGLE	ROLL-THRU HEATED CABINET	59	7.2 A	120/208	1	FA	CLG	E.C. TO BRANCH TO CONNECTION AS REQUIRED
E16	DC/DUPLEX	CONVENIENCE OUTLET	-	16.0 A	120	1	FA	CLG	E.C. TO BRANCH TO CONNECTION AS REQUIRED
E17	DC/DUPLEX	ROLL-THRU REFRIGERATOR	60	16.4 A	120	1	FA	CLG	E.C. TO BRANCH TO CONNECTION AS REQUIRED
E18	SINGLE	HOT FOOD SERVING COUNTER	63	40.0 A	120/208	1	FLOOR	STUB	-
E19	DUPLEX	REFRIGERATED DISPLAY	64	16.0 A	120	1	FLOOR	STUB	-
E20	DUPLEX	EDP/POS SYSTEM	69	10.0 A	120	1	FLOOR	STUB	E.C. TO VERIFY ELECTRICAL REQUIREMENTS W/OWNER
E21	E.C. TO PROVIDE EMPTY CONDUIT WITH JUNCTION BOX FOR OWNER SUPPLIED EDP/POS SYSTEM & PRINTER. VERIFY REQUIREMENTS AND LOCATIONS WITH OWNER/OPERATOR EDP/POS PLANS.								
E22	SINGLE	HOT FOOD SERVING COUNTER	71	40.0 A	120/208	1	FLOOR	STUB	-
E23	DUPLEX	WASHER	77	V.F.Y.	V.F.Y.	V.F.Y.	WALL	18"	E.C. TO VERIFY ELECTRICAL REQUIREMENTS W/OWNER
E24	SINGLE	DRYER	78	V.F.Y.	V.F.Y.	V.F.Y.	WALL	18"	E.C. TO VERIFY ELECTRICAL REQUIREMENTS W/OWNER
E25	JUNCT. BOX	REMOTE CONDENSING UNIT	82	1.5 HP	208	3	V.F.Y.	V.F.Y.	E.C. TO BRANCH TO CONNECTION AS REQUIRED
E26	JUNCT. BOX	REMOTE CONDENSING UNIT	83	3.5 HP	208	3	V.F.Y.	V.F.Y.	E.C. TO BRANCH TO CONNECTION AS REQUIRED
E27	E.C. TO PROVIDE EMPTY OCTAGONAL BOX FOR REMOTE PULL STATION AS REQUIRED						WALL	48"	AT POINT OF EGRESS PER LOCAL CODE

ELECTRICAL SYMBOLS

DUPLEX RECEPTACLE, NEMA 5-20R	DR	⊕
SINGLE RECEPTACLE, 208 OR 480	SR	⊕
JUNCTION BOX	JB	⊕
DROP CORD OR CONDUIT	DC	⊕
SWITCH	S	S
FLUORESCENT LIGHT		⊕
POINT OF CONNECTION ON EQUIPMENT		⊕
VAPOR-PROOF LIGHTS		⊕
PULL BOX-FIRE SUPPRESSION		⊕

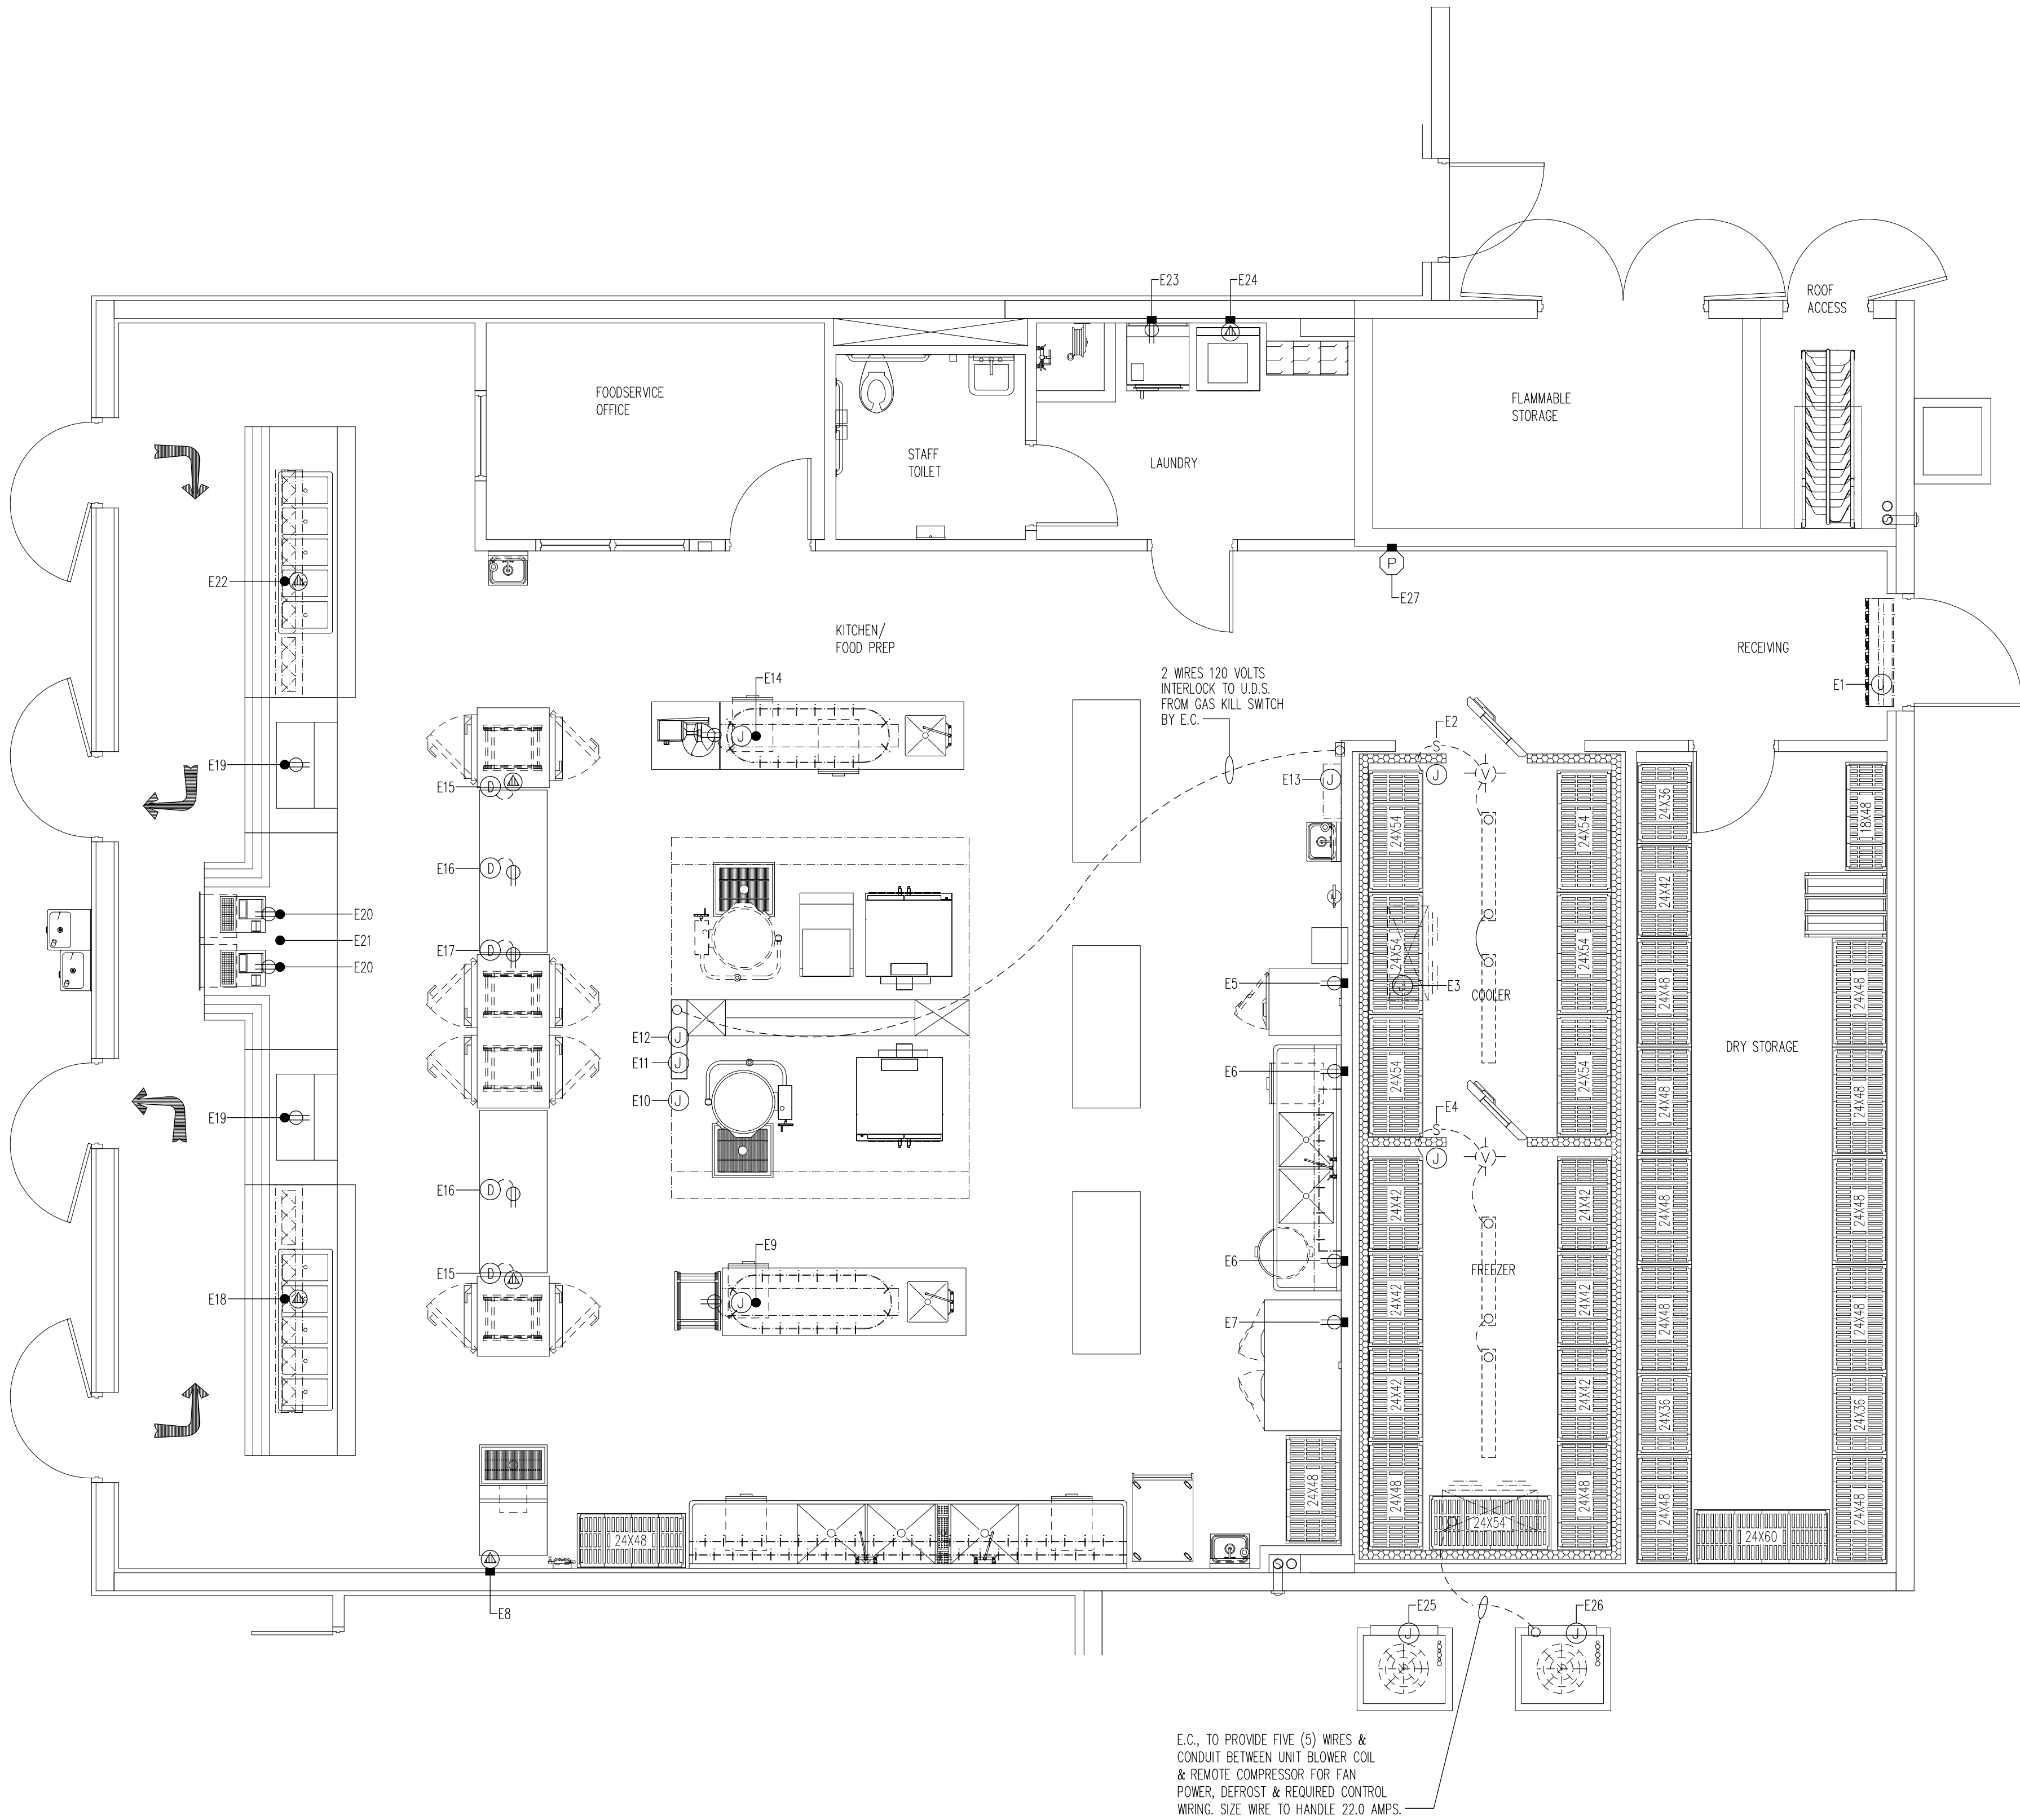

ALL DRAWINGS WRITTEN SPECIFICATIONS AND DETAILS APPEARING HEREIN CONSTITUTE THE ORIGINAL AND UNPUBLISHED WORK OF INMAN FOODSERVICES GROUP - LLC, AND MAY NOT BE DUPLICATED, USED, OR DISCLOSED WITHOUT THE EXPRESS WRITTEN CONSENT OF INMAN FOODSERVICES GROUP - LLC.

NEW ELEMENTARY SCHOOL (K-5) VENETIAN PARC WEST


SOUTHWEST 157th AVENUE and 174th STREET
MIAMI, FL. 33187
MDCPS PROJECT No. 01892600

CONSULTANT INFO:



• NASHVILLE
• MIAMI
• SAN ANTONIO

KEY PLAN

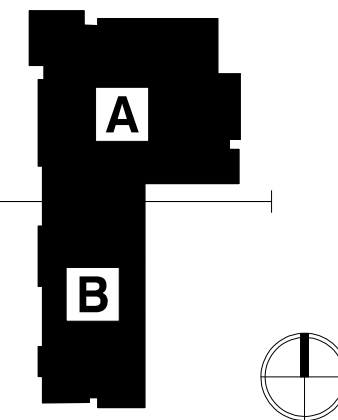

CONSULTANT INFO:



MODEL A: RODRIGUEZ, RAI
FLOOR BOILER ROOM (F.B.R.) 10000
FLOOR BOILER ROOM (F.B.R.) 11630

**RODRIGUEZ
ARCHITECTS
INCORPORATED**
2121 PONCE DE LEON BLVD. STE.
1010 CORAL GABLES, FL. 33134
TEL: (305) 448-3373
FAX: (305) 448-3374

RAI

REVISIONS:

DRAWING TITLE:

**ELECTRICAL PLAN
AND SCHEDULE**

SCALE: 1/4" = 1'-0"

ISSUE DATE:

12.16.19

PROJECT NO.

1906

SHEET:

FS-1.3

SPECIAL CONDITIONS NOTES

ALL DIMENSIONS SHOWN ARE FROM FINISHED WALLS, FLOORS, CEILINGS AND/OR FROM CENTER LINE OF STRUCTURAL COLUMNS. DIMENSIONS ARE TO BE VERIFIED BY THE KITCHEN EQUIPMENT CONTRACTOR AND ALL TRADES UTILIZING THESE PLANS.

ANY "HOLD" DIMENSIONS ARE CLEAR "FINISH-TO-FINISH" UNLESS OTHERWISE NOTED.

REFER TO ARCHITECTURAL/ENGINEERING DRAWINGS FOR ACTUAL CONSTRUCTION DIMENSIONS, LOCATION, THICKNESS AND FINISH OF PARTITIONS, FURRING AND DOOR SIZES AND LOCATIONS NOT INDICATED ON THE SPECIAL CONDITIONS PLAN.

CEILINGS SHALL BE SMOOTH, NON-ABSORBENT, WASHABLE AND LIGHT COLORED, BY GENERAL CONTRACTOR.

GENERAL CONTRACTOR TO FURNISH AND INSTALL ANGLE IRON TO UNDERSIDE OF BUILDING STRUCTURE ABOVE TO SUPPORT EXHAUST VENTILATOR. COORDINATE INSTALLATION WITH THE KITCHEN EQUIPMENT CONTRACTOR.

DEPRESSIONS FOR WALK-IN FREEZER/COOLER ASSEMBLIES AND/OR FLOOR TROUGHS SHALL BE SMOOTH AND TRANSIT-LEVEL. REFER TO PLAN FOR SIZES, DEPTHS AND ADDITIONAL INFORMATION.

CONCRETE AND MASONRY BASES AND CURBS SHALL BE SMOOTH AND TRANSIT-LEVEL. ALL EXPOSED SURFACES SHALL BE FINISHED THE SAME AS FINISHED FLOOR. REFER TO PLAN FOR SIZES AND ADDITIONAL INFORMATION.

UTILITY CURBS SHALL BE UTILIZED IN KITCHEN AND DISHWASHING AREAS, TO FACILITATE THE CLEANING OF FLOORS IN WET AREAS. CONTRACTOR SHALL GROUP AND CONSOLIDATE THE STUB-UPS INTO GROUPS WHERE POSSIBLE TO MINIMIZE THE NUMBER OF CURBS.

ALL BACKING MATERIALS SUITABLE FOR WALL-MOUNTED EQUIPMENT SHALL BE PROVIDED BY GENERAL CONTRACTOR AS DETAILED.

ALL STRUCTURE SUPPORT MATERIALS AND BRACING SUITABLE FOR CEILING HUNG EQUIPMENT SHALL BE PROVIDED BY THE GENERAL CONTRACTOR. COORDINATE INSTALLATION WITH THE KITCHEN EQUIPMENT CONTRACTOR.

ALL RACKS AND/OR PLATFORMS FOR ROOF-MOUNTED EQUIPMENT AND COMPRESSOR RACKS SHALL BE PROVIDED BY GENERAL CONTRACTOR.

ALL WALL, FLOOR AND/OR ROOF SLEEVES SHALL BE PROVIDED BY GENERAL CONTRACTOR.

KITCHEN EQUIPMENT CONTRACTOR SHALL UNDER NO CONDITIONS SET-IN-PLACE OR INSTALL ANY PIECE OF EQUIPMENT PRIOR TO TILE FLOORS BEING ACID WASHED AND FINISHED.

WHERE QUARRY TILE FLOORS ARE EXTENDED INTO WALK-IN FREEZER/COOLER ASSEMBLIES, GENERAL CONTRACTOR SHALL PROTECT ALL EXPOSED METAL SURFACES AND REMOVE DOORS PRIOR TO ACID WASHING OF FLOORS AND PROVIDE POWER VENTILATION TO REMOVE FUMES.

GENERAL CONTRACTOR SHALL PROVIDE WALL OPENINGS TO ACCOMMODATE ITEMS OF PASS-THRU AND CONVEYOR EQUIPMENT AS DETAILED ON PLAN. REFER TO PLAN FOR ADDITIONAL INFORMATION.

16 GAUGE STAINLESS STEEL CORNER GUARDS SHALL BE FURNISHED AND INSTALLED BY KITCHEN EQUIPMENT CONTRACTOR AS PER PLANS AND DETAILS.

WHEN QUARRY TILE FLOORING IS PROVIDED IN THE FOOD SERVICE AREAS AND INSIDE THE COOLER AND FREEZER ASSEMBLIES, THE GENERAL CONTRACTOR SHALL PROTECT ALL EXPOSED FOODSERVICE EQUIPMENT METAL SURFACES. DURING GROUTING AND A CID WASHING OF FLOORING, GENERAL CONTRACTOR TO PROVIDE POWER VENTILATION TO REMOVE FUMES FROM ALL FOODSERVICE AREAS. RESULTING DAMAGE TO STAINLESS STEEL AS A RESULT OF ACID DAMAGE IS UNREPAIRABLE. AS ACID WASH FUMES CHANGE THE METAL COMPOSITION OF STAINLESS STEEL, GENERAL CONTRACTOR WILL BE RESPONSIBLE TO REPLACE ALL ACID DAMAGED FOODSERVICE EQUIPMENT AND COOLER/FREEZER PANELS.

VENTILATION NOTES

VENTILATION DUCTWORK, EXHAUST FANS, SUPPLY FANS, INTERLOCKS, MOTOR STARTERS, DISCONNECT SWITCHES, FAN CONTROLS, SWITCHES, INTERCONNECTING WIRING, CONDUIT, AND FINAL CONNECTIONS (TO AND FROM) VENTILATORS AND/OR DISHWASHER CONDENSATE HOODS SHALL BE FURNISHED BY THE H.V.A.C./MECHANICAL CONTRACTOR, AND SPECIFIED BY THE MECHANICAL ENGINEER.

DISHWASHER CONDENSATE DUCT AND EXHAUST VENTILATOR SUPPLY AND EXHAUST, DUCT SIZES AND ALL OTHER VENTILATION SPECIFICATIONS FROM THE DUCT COLLAR ON SHALL BE DETERMINED BY ARCHITECT/ENGINEER AND ALL NECESSARY MATERIAL AND LABOR PROVIDED FURNISH BY THE H.V.A.C./MECHANICAL CONTRACTOR, AND SPECIFIED BY THE MECHANICAL ENGINEER.

VENTILATION CFM, STATIC PRESSURE AND DUCT SIZES INDICATED ON THESE PLANS ARE THE SPECIFIED EQUIPMENT MINIMUM REQUIREMENTS.

THE FOLLOWING MINIMUM GENERAL FOODSERVICE VENTILATION REQUIREMENTS ARE RECOMMENDED:

A. COOKING, PREPARATION, POTWASHING AND DISHWASHING AREAS: 15 CFM PER PERSON.

B. STORAGE AREAS: 2-3 AIR CHANGES PER HOUR, 75° FAHRENHEIT MAXIMUM AMBIENT TEMPERATURE.


C. OFFICE AREAS: 20 CFM PER PERSON.

D. AIR-COOLED REFRIGERATION CONDENSING UNITS: 1000 CFM PER HORSEPOWER SUPPLY AND EXHAUST, 90° FAHRENHEIT MAXIMUM AMBIENT TEMPERATURE.

E. WATER-COOLED REFRIGERATION CONDENSING UNITS: 250 CFM PER HORSEPOWER SUPPLY AND EXHAUST, 90° FAHRENHEIT MAXIMUM AMBIENT TEMPERATURE. ALL AREAS MUST BE VENTILATED AS REQUIRED BY APPLICABLE GOVERNING CODES.

MAKE-UP AIR SYSTEM SHALL BE DESIGNED TO PROVIDE A 10% TO 20% NEGATIVE AIR PRESSURE IN KITCHEN AREAS TO CONTAIN SMOKE AND ODORS. MAKE-UP AIR SHOULD BE HEATED OR AIR CONDITIONED AS APPLICABLE.

ADEQUATE VENTILATION (24 HOURS) IS REQUIRED FOR SELF-CONTAINED REFRIGERATION UNITS IN ENCLOSED AREAS, SUCH AS, ICE MAKERS, WALK-IN COOLER ASSEMBLIES, AND BEVERAGE SYSTEMS, TO PREVENT OVERHEATING AND COMPRESSOR FAILURE.

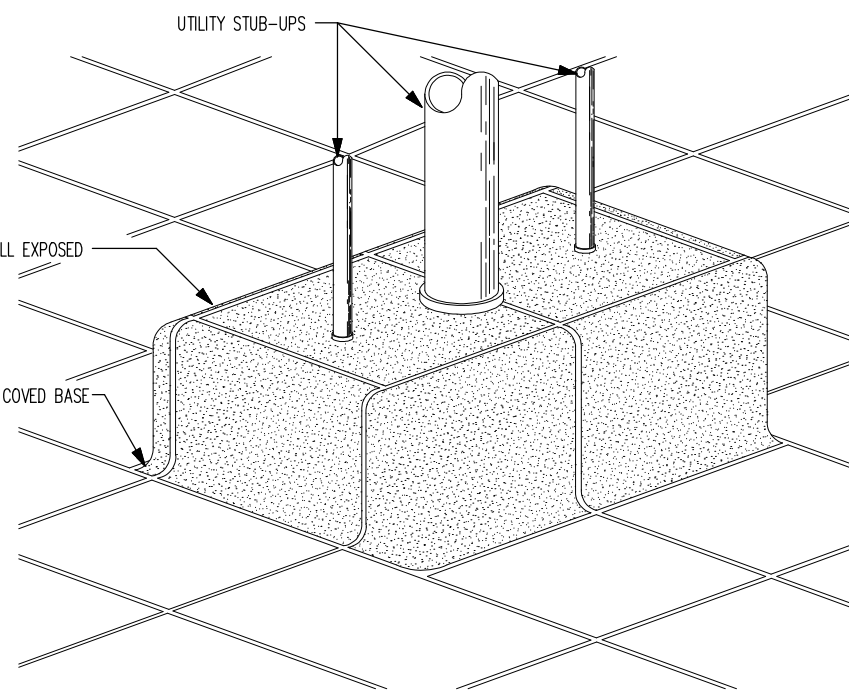

UTILITY CURB


NOTE:
UTILITY CURBS SHALL BE UTILIZED IN KITCHEN AND DISHWASHING AREAS, TO FACILITATE THE CLEANING OF FLOORS IN WET AREAS. CONTRACTOR SHALL GROUP AND CONSOLIDATE THE STUB-UPS INTO GROUPS WHERE POSSIBLE TO MINIMIZE THE NUMBER OF CURBS.

VENTILATION CONNECTIONS SCHEDULE


NUMBER	QTY.	SIZE	CONNECTION	C.F.M.	F.P.M.	S.P.	REMARKS
V01	1	10" X 10"	EXHAUST	250	-	-	POWER EXHAUST
V02	1	10" X 17"	EXHAUST	1850	-	-0.919"	-
V03	3	10" X 24"	SUPPLY	483	-	0.134"	-
V04	1	10" X 19"	EXHAUST	2004	-	-0.928"	-
V05	3	10" X 24"	SUPPLY	534	-	0.134"	-

VENTILATION SYMBOLS

 EXHAUST DUCT



SUPPLY DUCT

 

STATIC PRESSURE,
WATER GAUGE

SPWG

CUBIC FEET/MINUTE

 
CFM

SPECIAL CONDITIONS SYMBOLS


SLAB DEPRESSION





BLOCKOUT



RAISED CURB

 

WALL BACKING

 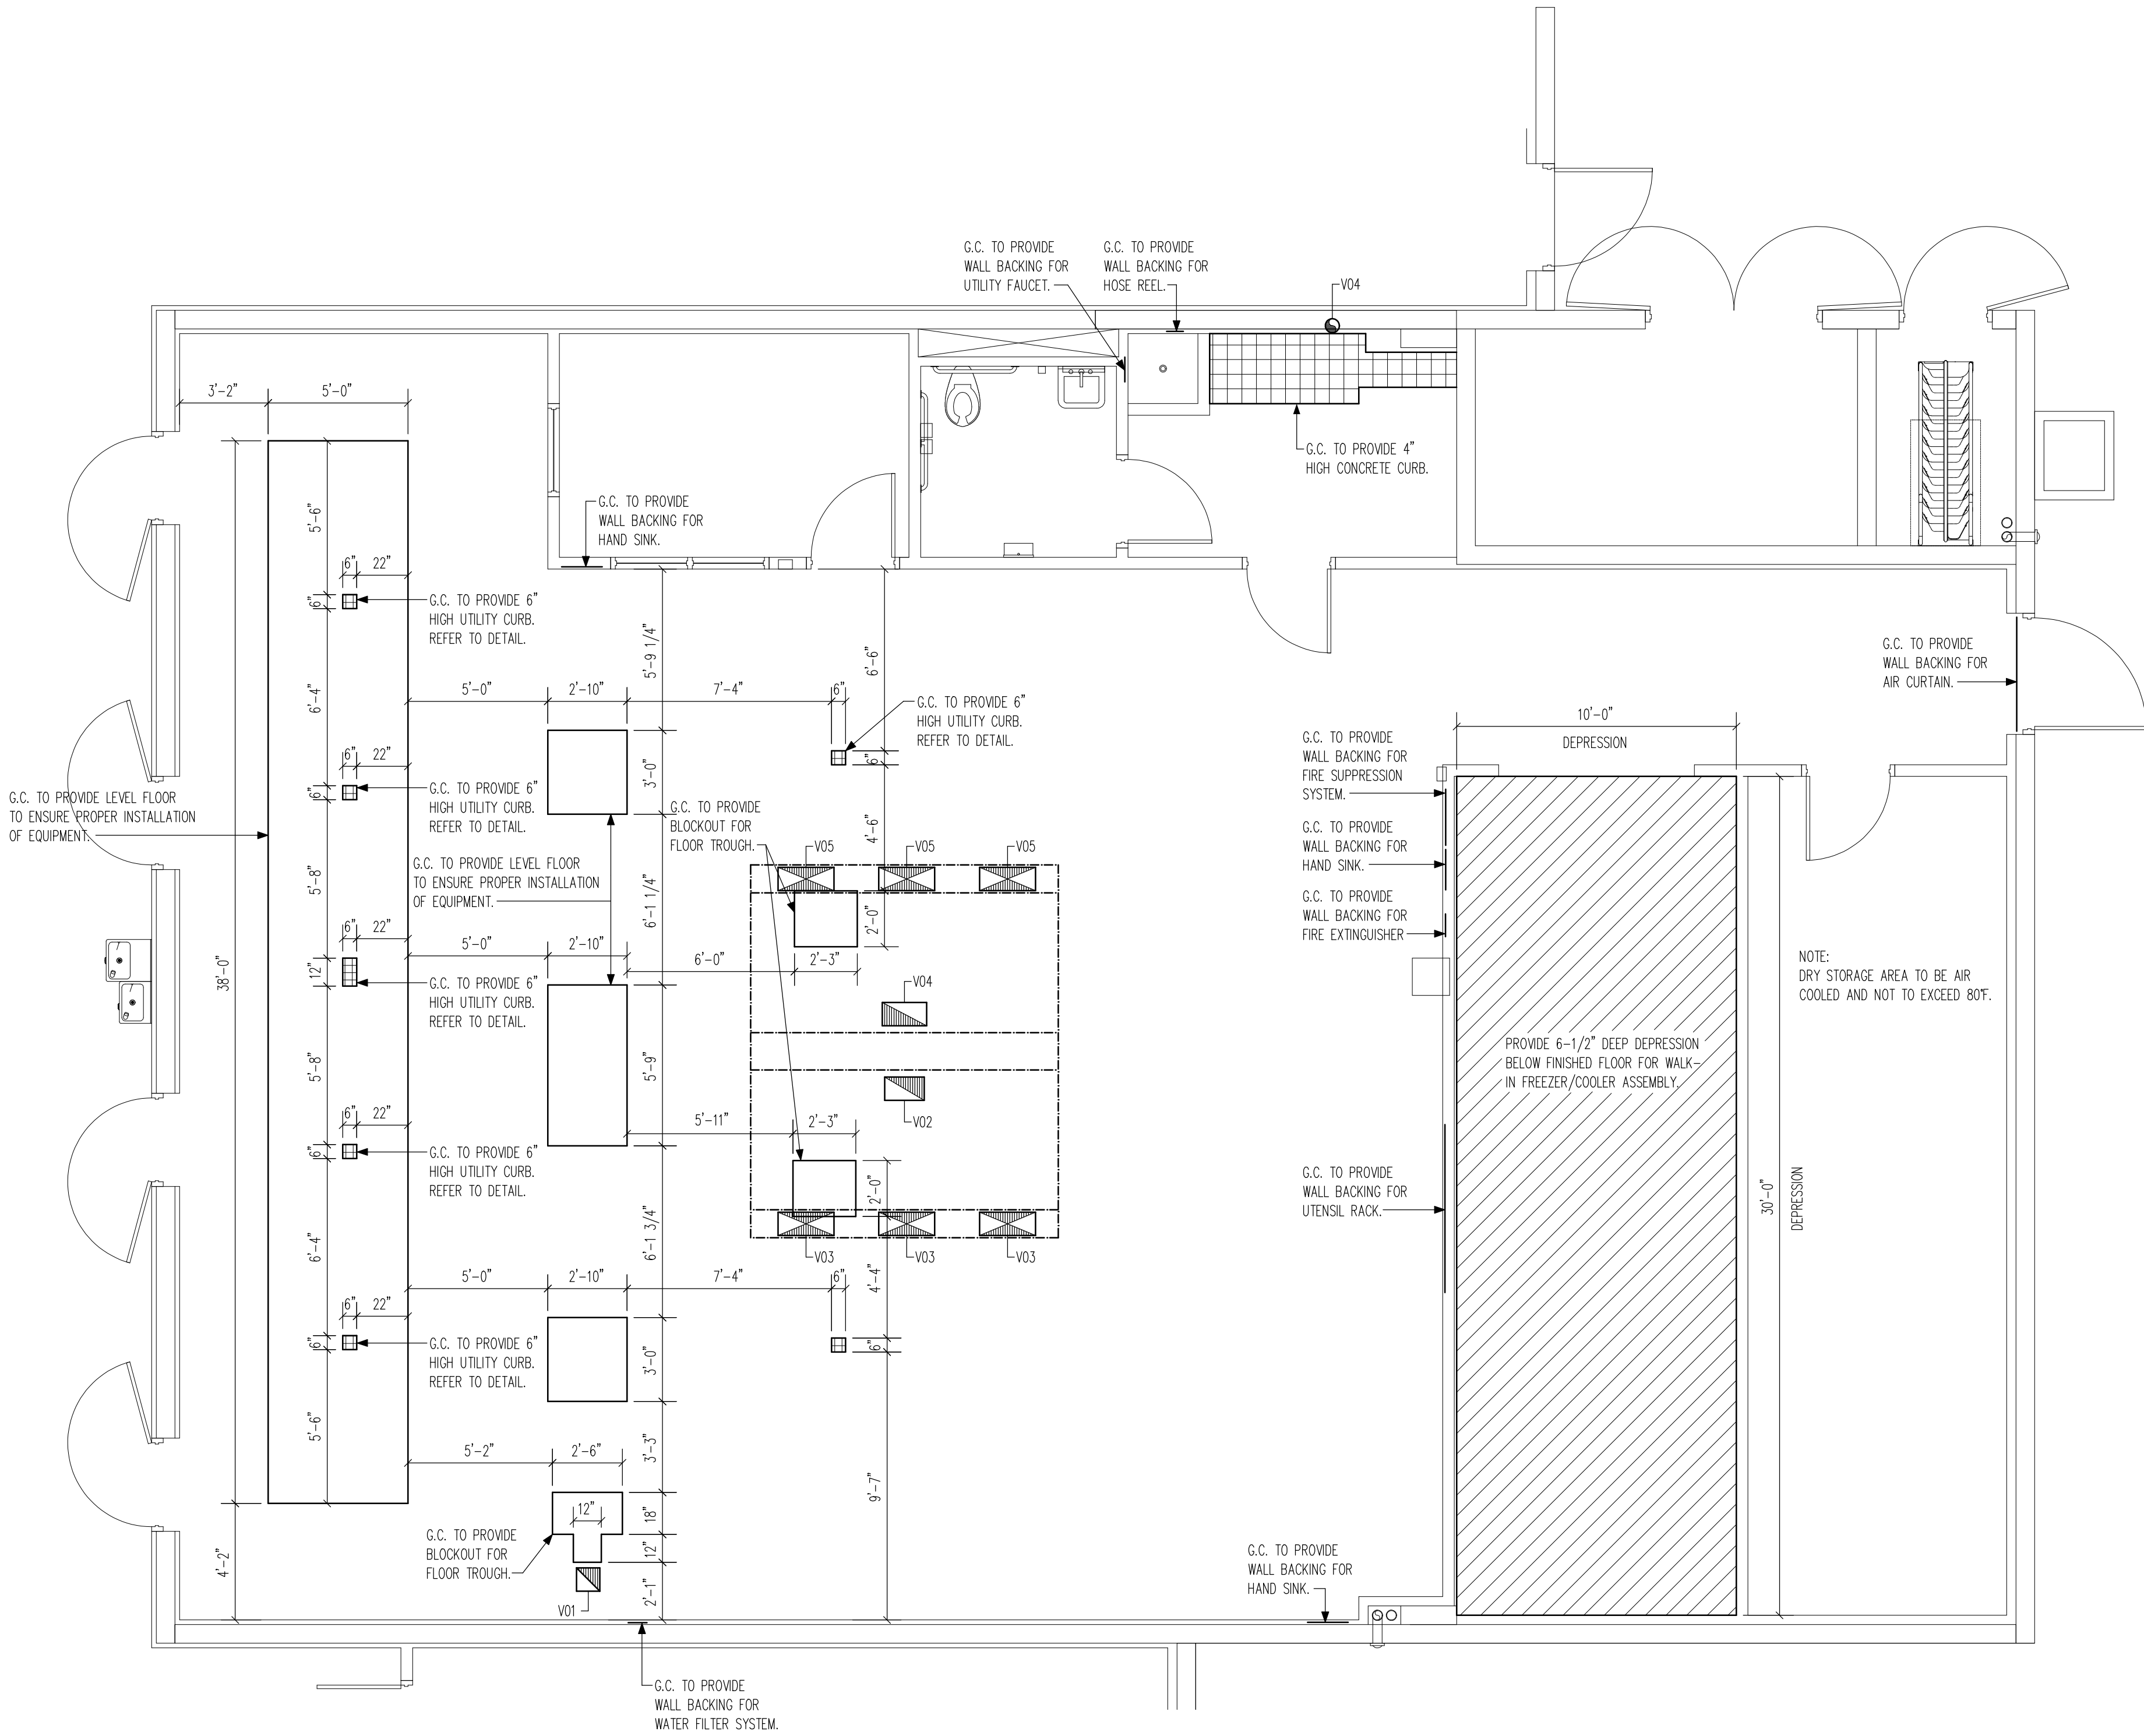

ALL DRAWINGS WRITTEN SPECIFICATIONS AND DETAILS APPEARING HEREIN CONSTITUTE THE ORIGINAL AND UNPUBLISHED WORK OF INMAN FOODSERVICES GROUP - LLC, AND MAY NOT BE DUPLICATED, USED, OR DISCLOSED WITHOUT THE EXPRESS WRITTEN CONSENT OF INMAN FOODSERVICES GROUP - LLC.


NEW ELEMENTARY SCHOOL (K-5)

VENETIAN PARC WEST

SOUTHWEST 157th AVENUE and 174th STREET
MIAMI, FL. 33187

MDCPS PROJECT No. 01892600

KEY PLAN

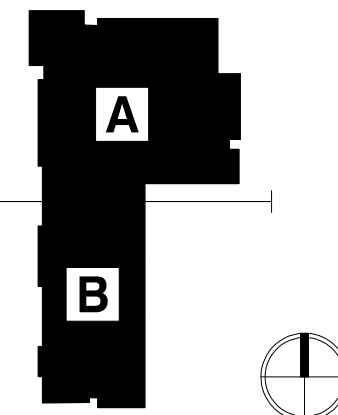

CONSULTANT INFO:



MODEL A: BLOCKOUT, F.A.I.
FLOOR BLOCKOUT, F.A.I. 10000
FLOOR BLOCKOUT, F.A.I. 11630

RODRIGUEZ ARCHITECTS INCORPORATED
2121 PONCE DE LEON BLVD. STE.
1010 CORAL GABLES, FL. 33134
TEL: (305) 448-3373
FAX: (305) 448-3374

RAI

REVISIONS:

DRAWING TITLE:

**SPECIAL CONDITIONS
PLAN AND SCHEDULE**

SCALE: 1/4" = 1'-0"

ISSUE DATE:

12.16.19

 
PROJECT NO:

1906


SHEET:


FS-1.4

ALL COMPLETED REFRIGERATION SYSTEMS MUST BE EVACUATED TO 300 MICRONS OR LESS WITH VACUUM PUMP.


C

FS-1.5

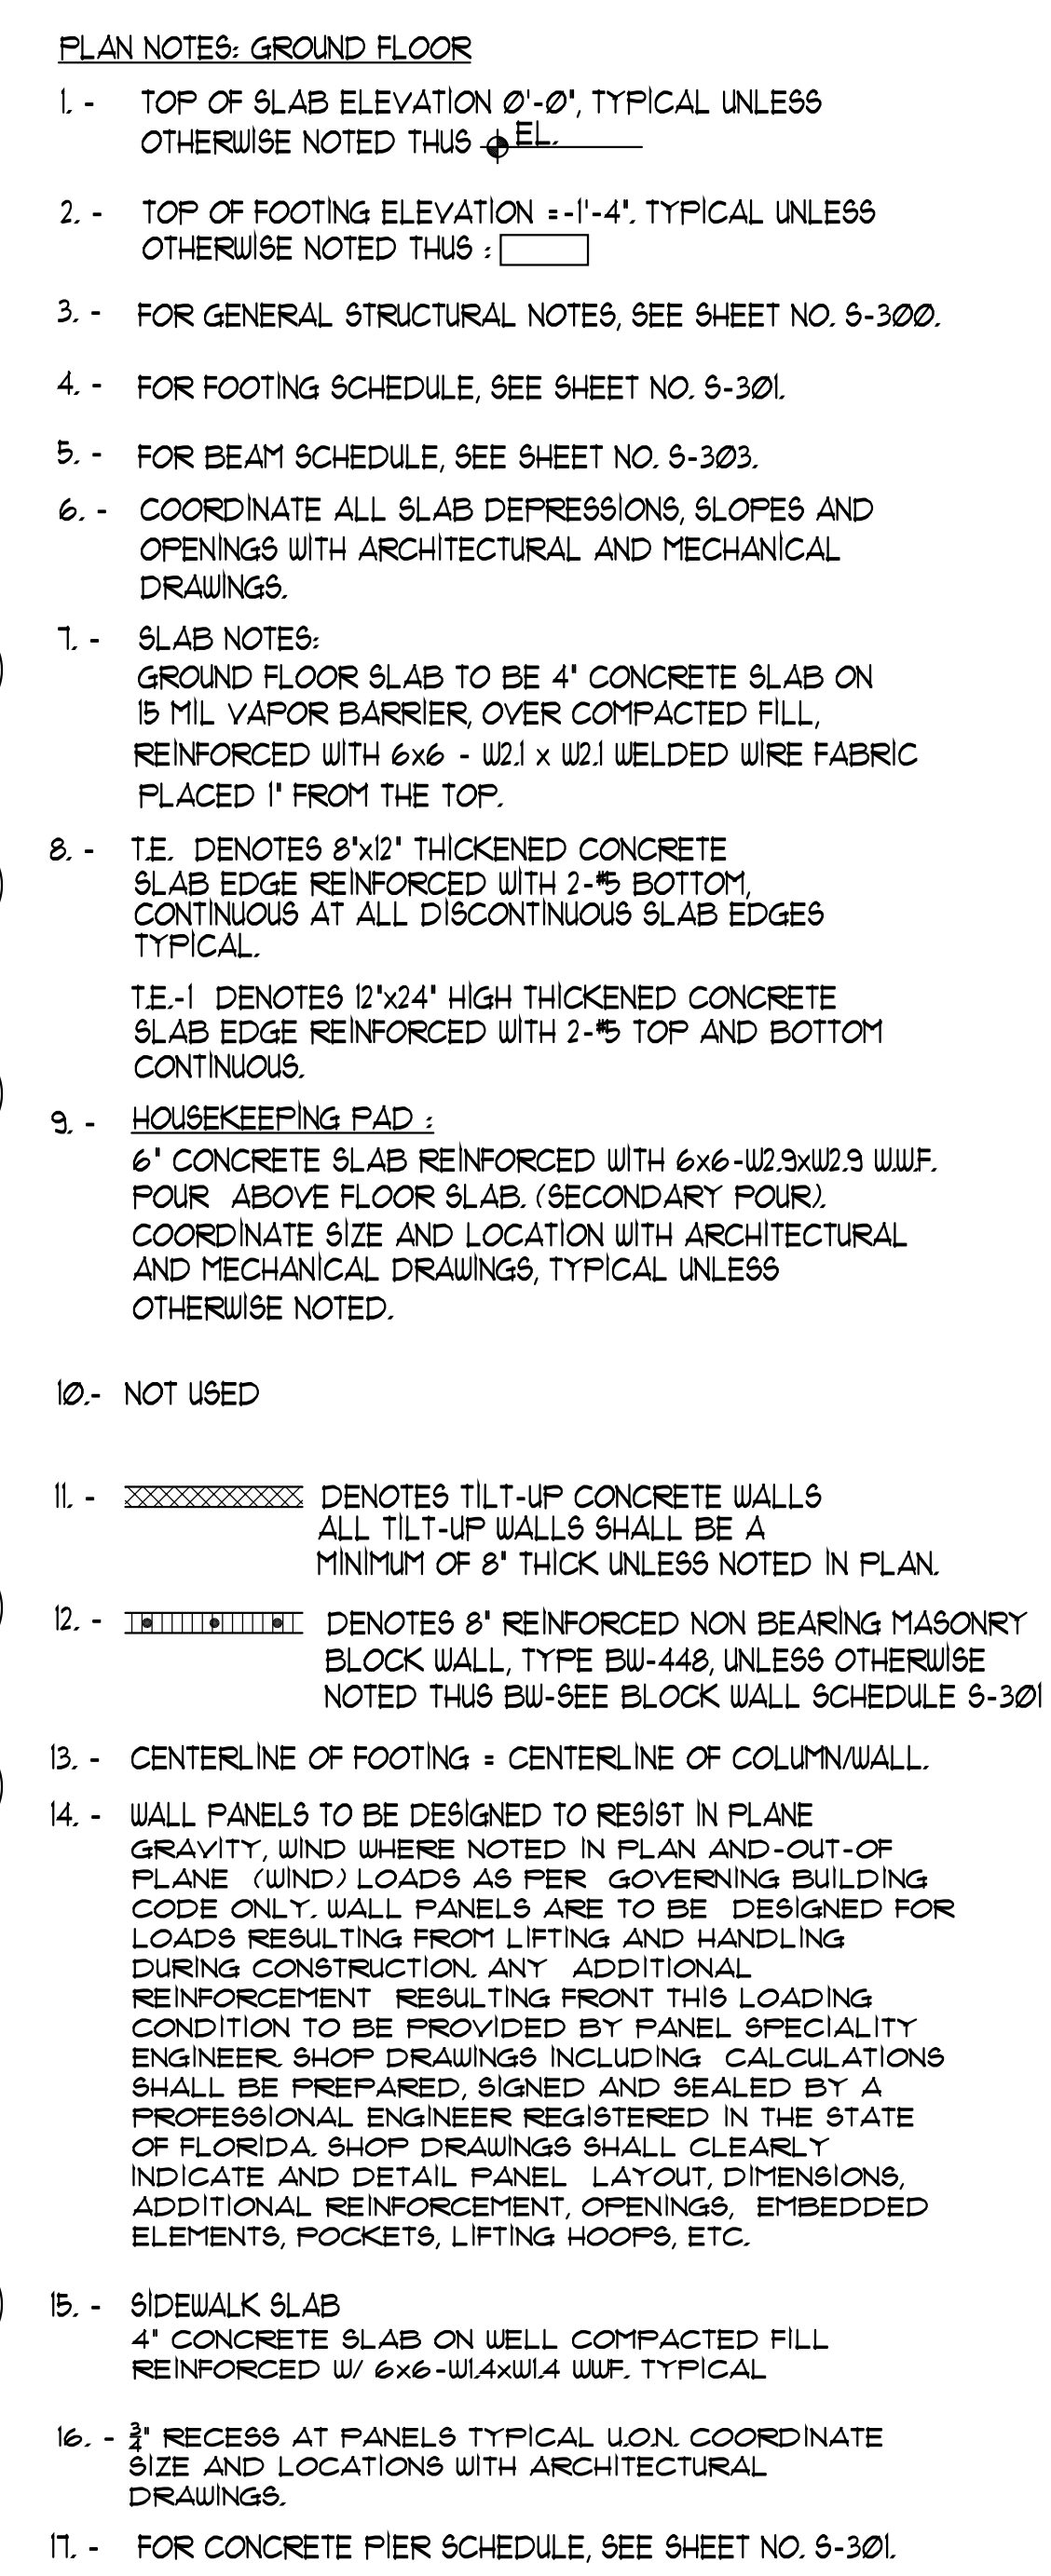

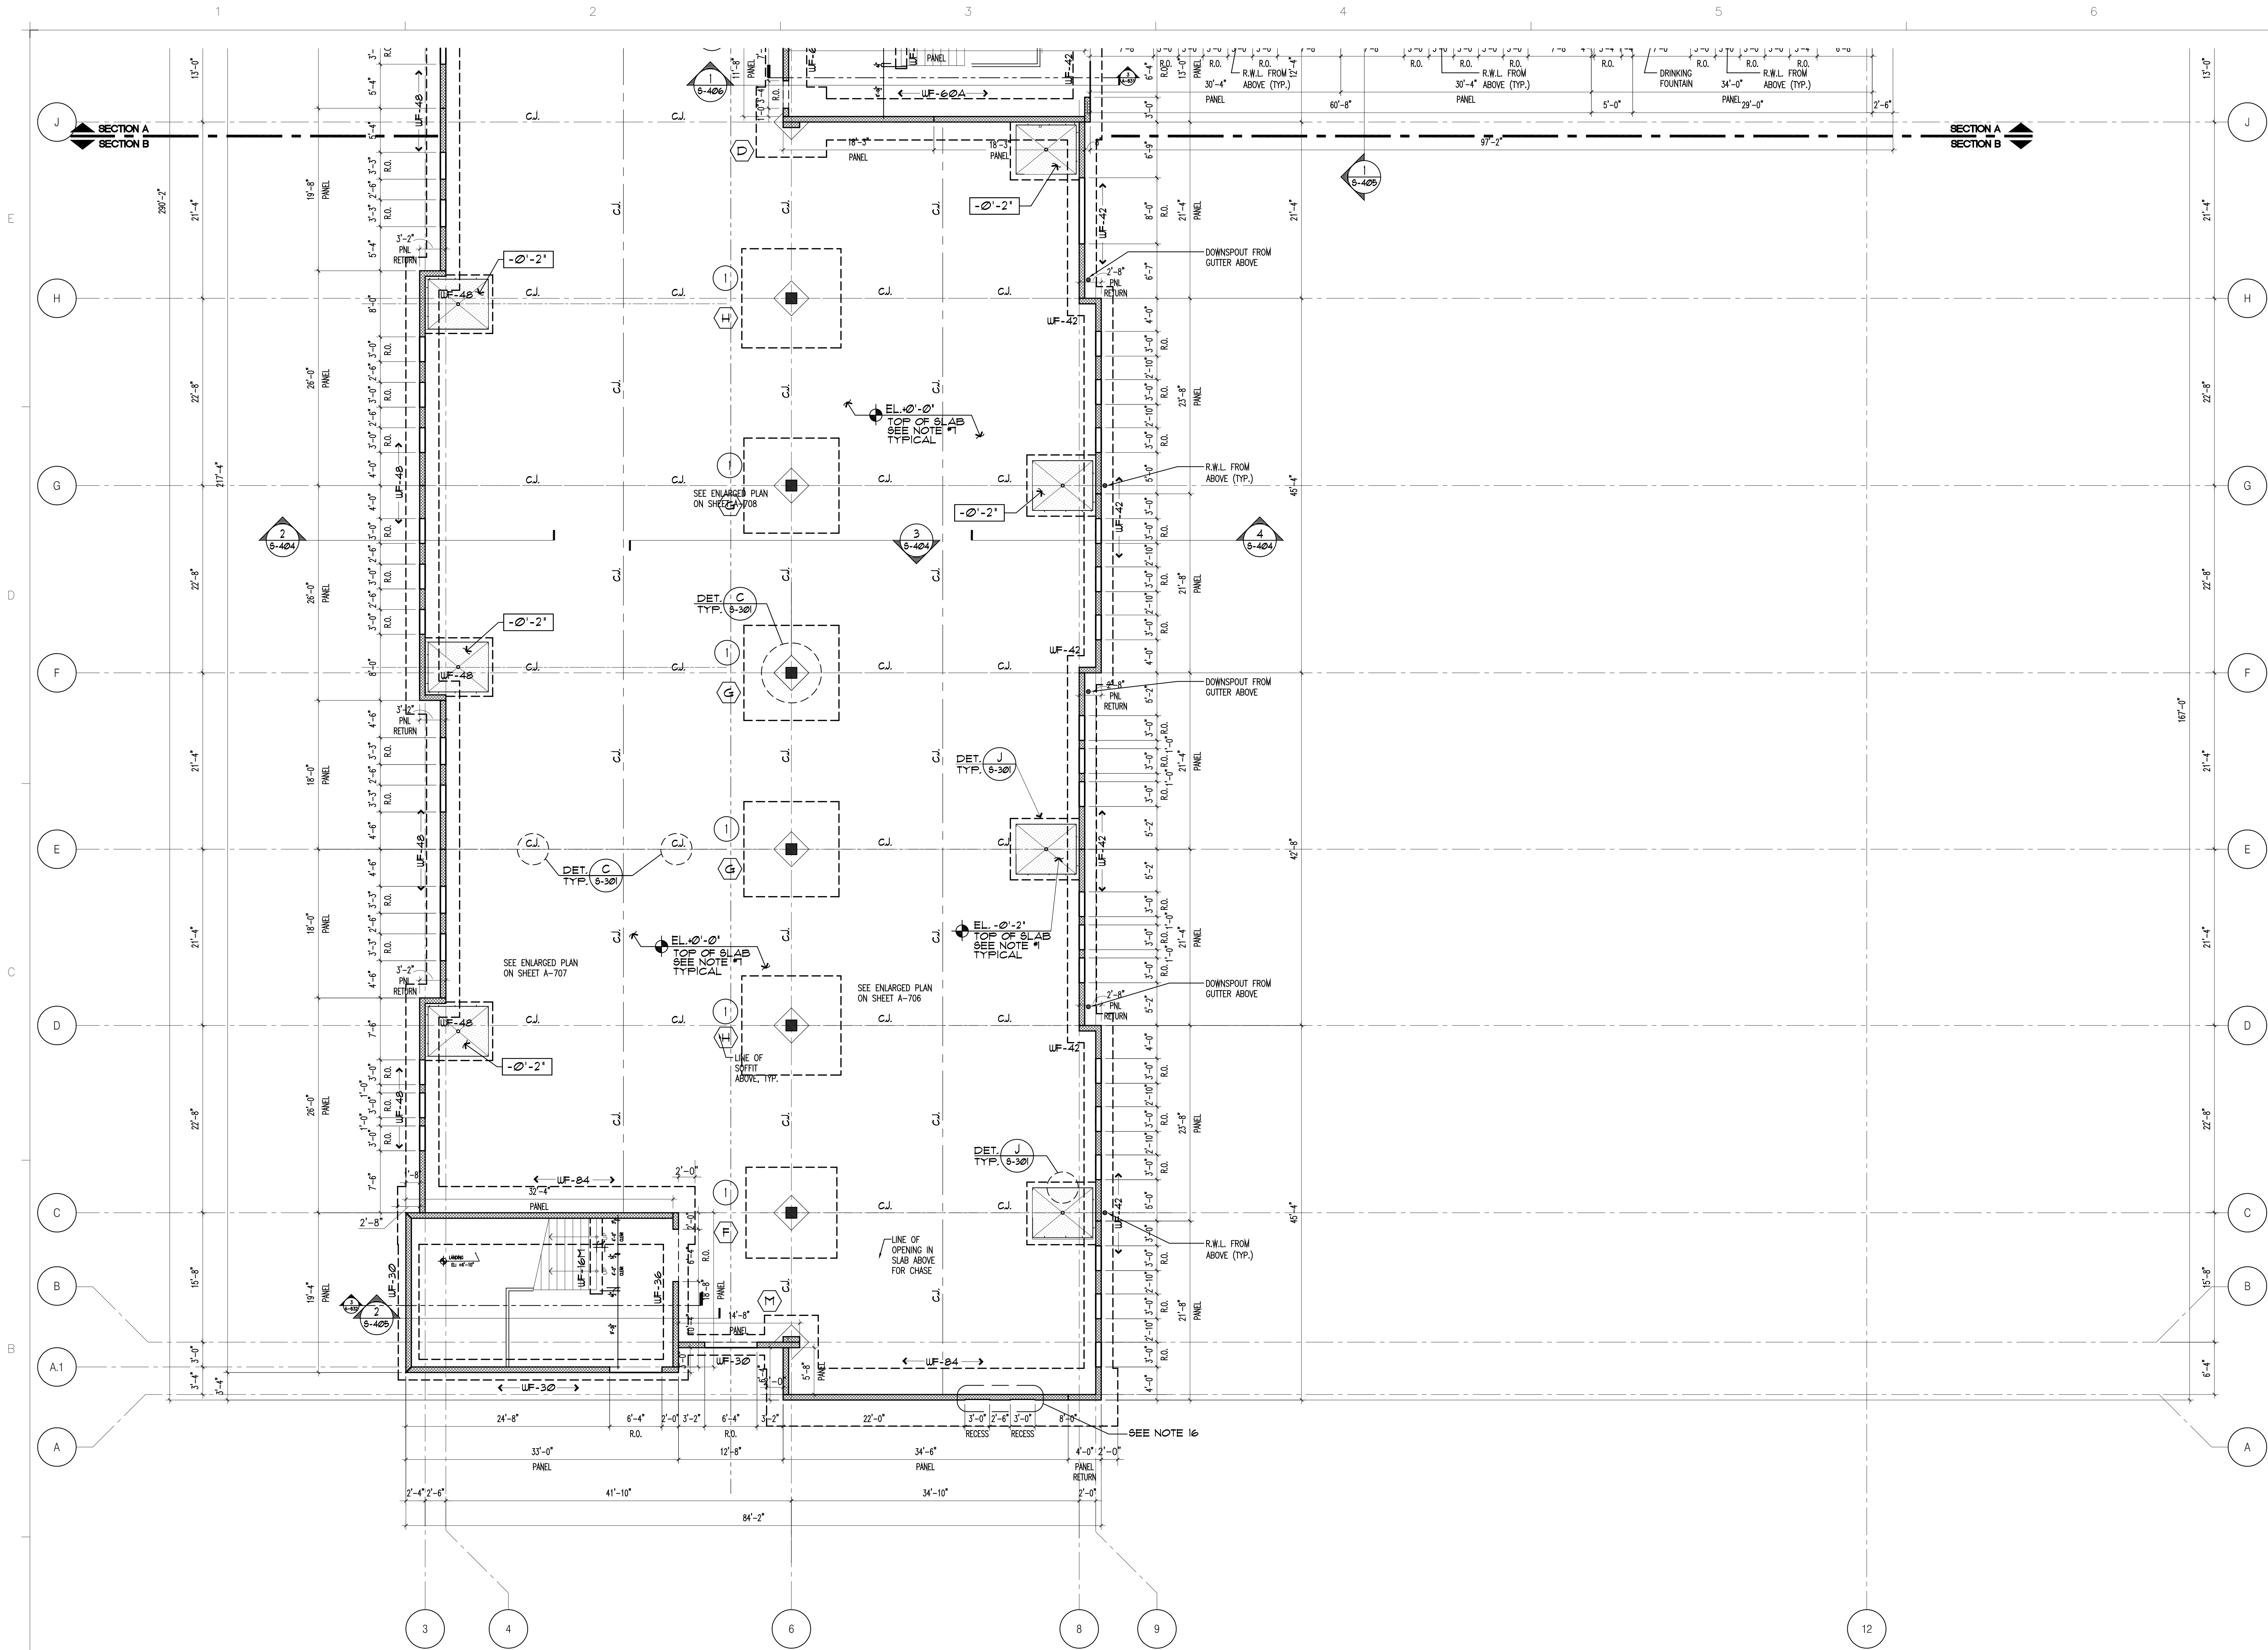



- PLAN NOTES: GROUND FLOOR
1. TOP OF SLAB ELEVATION 0'-0", TYPICAL UNLESS OTHERWISE NOTED THIS:
 2. TOP OF FOOTING ELEVATION +1'-4", TYPICAL UNLESS OTHERWISE NOTED THIS:
 3. FOR GENERAL STRUCTURAL NOTES, SEE SHEET NO. S-300.
 4. FOR FOOTING SCHEDULE, SEE SHEET NO. S-301.
 5. FOR BEAM SCHEDULE, SEE SHEET NO. S-302.
 6. COORDINATE ALL SLAB DEPRESSIONS, SLOPES AND OPENINGS WITH ARCHITECTURAL AND MECHANICAL DRAWINGS.
 7. SLAB NOTES:
GROUND FLOOR SLAB TO BE 4" CONCRETE SLAB ON 15 MIL VAPOR BARRIER, OVER COMPACTED FILL, REINFORCED WITH 6x6 - W2.1 x W2.1 WELDED WIRE FABRIC PLACED 1" FROM THE TOP.
 8. T.E. DENOTES 8"x12" THICKENED CONCRETE SLAB EDGE REINFORCED WITH 2-#5 BOTTOM CONTINUOUS AT ALL DISCONTINUOUS SLAB EDGES TYPICAL.
 9. HOUSEKEEPING PAD :
6" CONCRETE SLAB REINFORCED WITH 6x6-W2.3xW2.3 W.W.F. FOUR ABOVE FLOOR SLAB. (SECONDARY FOUR). COORDINATE SIZE AND LOCATION WITH ARCHITECTURAL AND MECHANICAL DRAWINGS, TYPICAL UNLESS OTHERWISE NOTED.
 10. NOT USED
 11. DENOTES TILT-UP CONCRETE WALLS
ALL TILT-UP WALLS SHALL BE A MINIMUM OF 8" THICK UNLESS NOTED IN PLAN.
 12. DENOTES 8" REINFORCED NON BEARING MASONRY BLOCK WALL, TYPE BU-448, UNLESS OTHERWISE NOTED THIS BU-SEE BLOCK WALL SCHEDULE S-301
 13. CENTERLINE OF FOOTING = CENTERLINE OF COLUMN/WALL.
 14. WALL PANELS TO BE DESIGNED TO RESIST IN PLANE GRAVITY, WIND WHERE NOTED IN PLAN AND -OUT-OF-PLANE (WIND) LOADS AS PER GOVERNING BUILDING CODE ONLY. WALL PANELS ARE TO BE DESIGNED FOR LOADS RESULTING FROM LIFTING AND HANDLING DURING CONSTRUCTION. ANY ADDITIONAL REINFORCEMENT RESULTING FROM THIS LOADING CONDITION TO BE PROVIDED BY PANEL SPECIALITY ENGINEER SHOP DRAWINGS INCLUDING CALCULATIONS SHALL BE PREPARED, SIGNED AND SEALED BY A PROFESSIONAL ENGINEER REGISTERED IN THE STATE OF FLORIDA. SHOP DRAWINGS SHALL CLEARLY INDICATE AND DETAIL PANEL LAYOUT, DIMENSIONS, ADDITIONAL REINFORCEMENT, OPENINGS, EMBEDDED ELEMENTS, POCKETS, LIFTING HOOPS, ETC.
 15. SIDEWALK SLAB
4" CONCRETE SLAB ON WELL COMPACTED FILL REINFORCED W/ 6x6-W1.4xW1.4 W.W.F. TYPICAL
 16. 3" RECESS AT PANELS TYPICAL U.O.N. COORDINATE SIZE AND LOCATIONS WITH ARCHITECTURAL DRAWINGS.

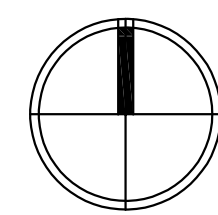

1 PARTIAL FOUNDATION & GROUND FLOOR PLAN - AREA B
S-222 Scale: 1/8" = 1'-0"

CONSULTANT INFO 4930 S.W. 74TH Court Miami, Florida, 33155 Phone: (305) 666-0711 Fax: (305) 666-6269 www.ddaeng.com 2019-42-A		 NEW ELEMENTARY SCHOOL (K-5) VENETIAN PARC WEST SOUTHWEST 157th AVENUE and 174th STREET MIAMI, FL. 33187 MDCPS PROJECT No. 01892600		KEY PLAN 		CONSULTANT INFO RODRIGUEZ ARCHITECTS INCORPORATED 2121 PONCE DE LEON BLVD. STE 1010 CORAL GABLES, FL. 33134 TEL: (305) 448-3373 FAX: (305) 448-3374 A A C -- 0 0 1 9 3 3		REVISIONS <table border="1"><thead><tr><th>NO.</th><th>DATE</th><th>DESCRIPTION</th></tr></thead><tbody><tr><td> </td><td> </td><td> </td></tr><tr><td> </td><td> </td><td> </td></tr><tr><td> </td><td> </td><td> </td></tr><tr><td> </td><td> </td><td> </td></tr></tbody></table>		NO.	DATE	DESCRIPTION													DRAWING TITLE: FOUNDATION & GROUND FLOOR PLAN AREA B SCALE AS NOTED ISSUE DATE: 10.11.19 PROJECT NO: 1906 SHEET: S-222	
NO.	DATE	DESCRIPTION																								

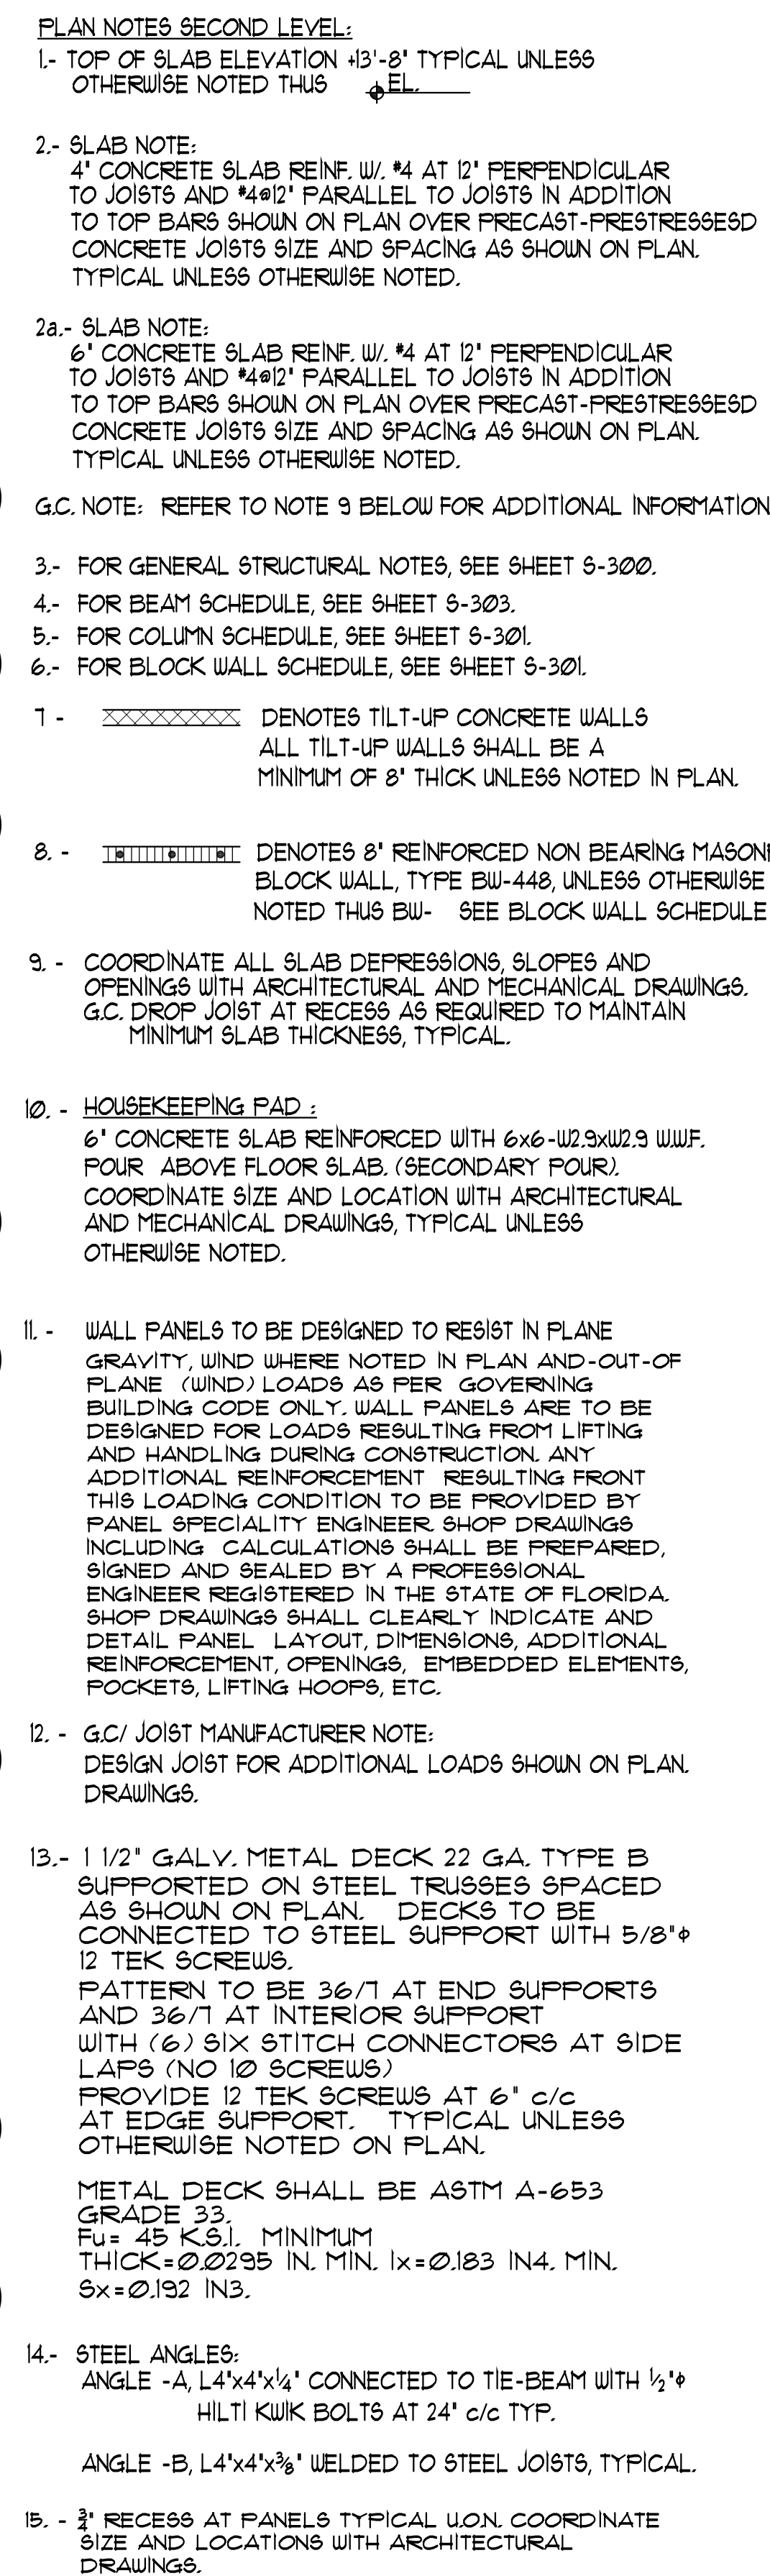

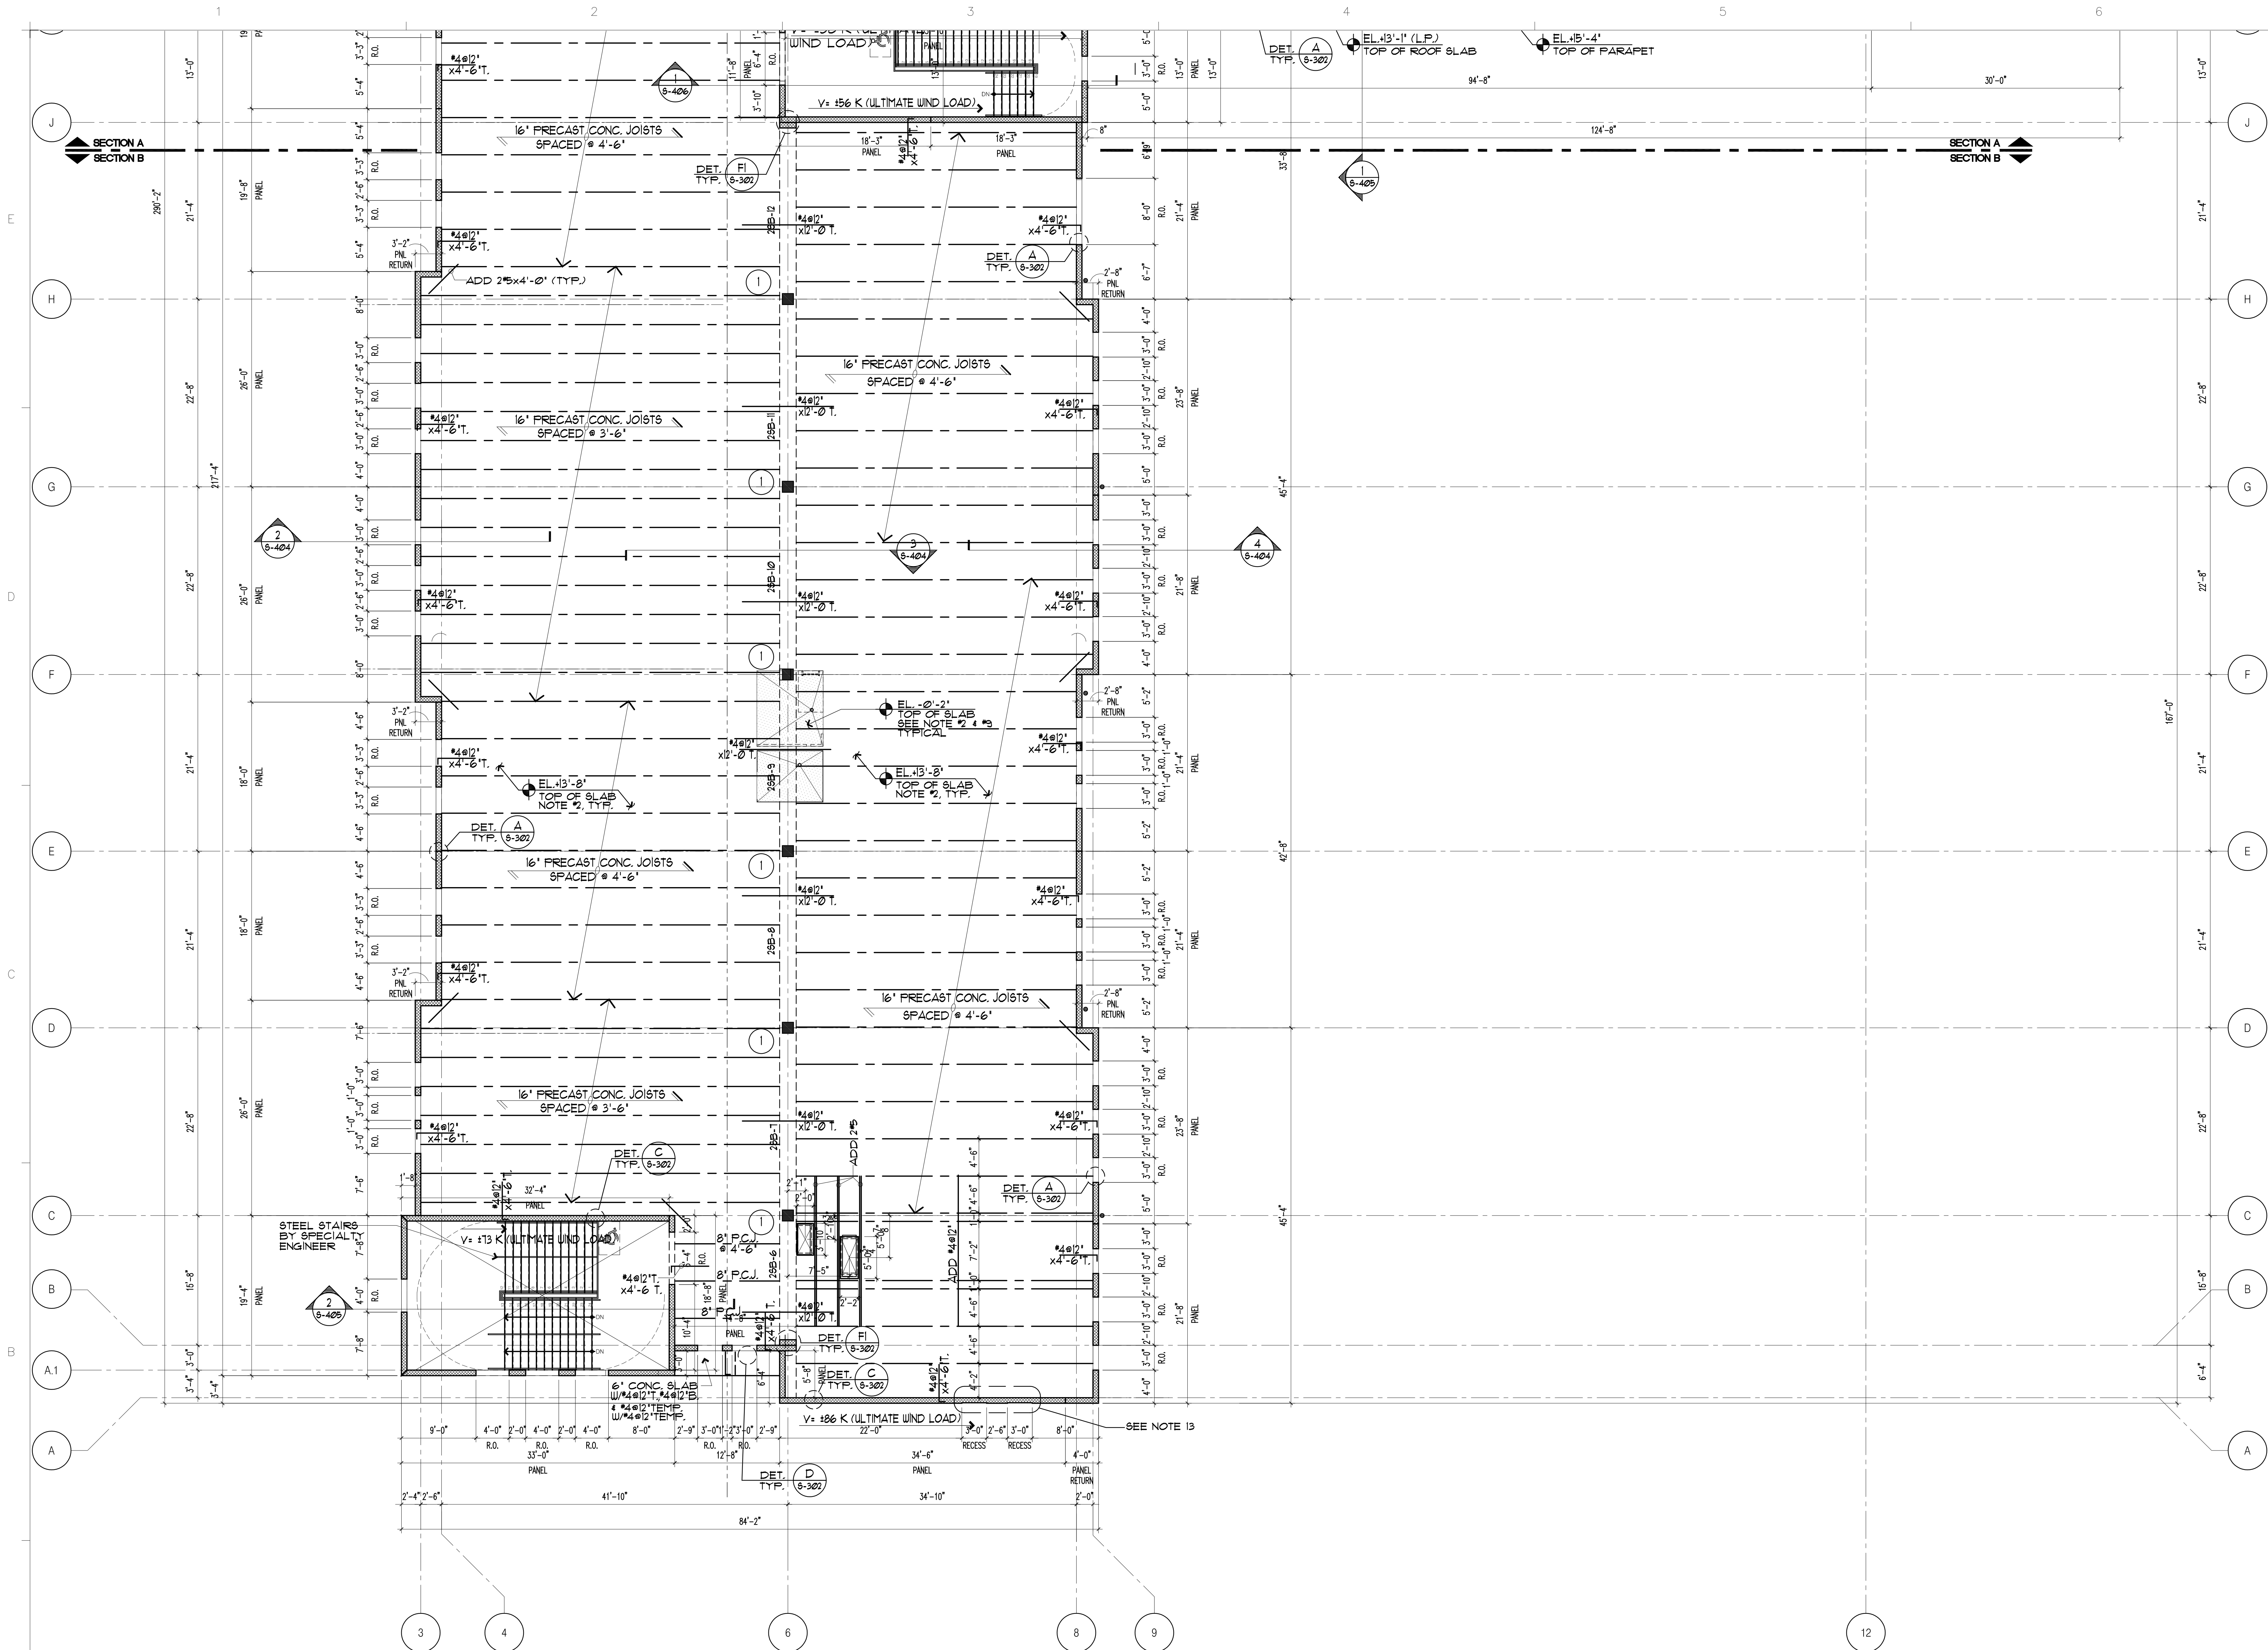

- PLAN NOTES SECOND LEVEL:
1. TOP OF SLAB ELEVATION 43'-8" TYPICAL UNLESS OTHERWISE NOTED THUS ∇ EL.
 2. SLAB NOTE:
4" CONCRETE SLAB REINF. W/ #4 AT 12" PERPENDICULAR TO JOISTS AND #4@12" PARALLEL TO JOISTS IN ADDITION TO TOP BARS SHOWN ON PLAN OVER PRECAST-POSTSTRESSED CONCRETE JOISTS SIZE AND SPACING AS SHOWN ON PLAN. TYPICAL UNLESS OTHERWISE NOTED.
 - G.C. NOTE: REFER TO NOTE 3 BELOW FOR ADDITIONAL INFORMATION.
 3. FOR GENERAL STRUCTURAL NOTES, SEE SHEET S-200.
 4. FOR BEAM SCHEDULE, SEE SHEET S-300.
 5. FOR COLUMN SCHEDULE, SEE SHEET S-301.
 6. FOR BLOCK WALL SCHEDULE, SEE SHEET S-301.
 7. DENOTES TILT-UP CONCRETE WALLS
ALL TILT-UP WALLS SHALL BE A MINIMUM OF 8" THICK UNLESS NOTED IN PLAN.
 8. DENOTES 8" REINFORCED NON BEARING MASONRY BLOCK WALL, TYPE BW-448, UNLESS OTHERWISE NOTED THUS BW- SEE BLOCK WALL SCHEDULE
 9. - COORDINATE ALL SLAB DEPRESSIONS, SLOPES AND OPENINGS WITH ARCHITECTURAL AND MECHANICAL DRAWINGS. G.C. DROP JOIST AT RECESS AS REQUIRED TO MAINTAIN MINIMUM SLAB THICKNESS, TYPICAL.
 10. - HOUSEKEEPING PAD:
6" CONCRETE SLAB REINFORCED WITH 6x6-W2.3xW2.3 WWF. FOUR ABOVE FLOOR SLAB. (SECONDARY FOUR). COORDINATE SIZE AND LOCATION WITH ARCHITECTURAL AND MECHANICAL DRAWINGS, TYPICAL UNLESS OTHERWISE NOTED.
 11. - WALL PANELS TO BE DESIGNED TO RESIST IN PLANE GRAVITY, WIND WHERE NOTED IN PLAN AND OUT-OF-PLANE (WIND) LOADS AS PER GOVERNING BUILDING CODE ONLY. WALL PANELS ARE TO BE DESIGNED FOR LOADS RESULTING FROM LIFTING AND HANDLING DURING CONSTRUCTION. ANY ADDITIONAL REINFORCEMENT RESULTING FROM THIS LOADING CONDITION TO BE PROVIDED BY PANEL SPECIALITY ENGINEER. SHOP DRAWINGS INCLUDING CALCULATIONS SHALL BE PREPARED, SIGNED AND SEALED BY A PROFESSIONAL ENGINEER REGISTERED IN THE STATE OF FLORIDA. SHOP DRAWINGS SHALL CLEARLY INDICATE AND DETAIL PANEL LAYOUT, DIMENSIONS, ADDITIONAL REINFORCEMENT, OPENINGS, EMBEDDED ELEMENTS, POCKETS, LIFTING HOOPS, ETC.
 12. - G.C./ JOIST MANUFACTURER NOTE:
DESIGN JOIST FOR ADDITIONAL LOADS SHOWN ON PLAN. DRAWINGS.
 13. - $\frac{3}{4}$ " RECESS AT PANELS TYPICAL U.O.N. COORDINATE SIZE AND LOCATIONS WITH ARCHITECTURAL DRAWINGS.

1 PARTIAL SECOND FLOOR FRAMING PLAN - AREA B
S-224 Scale: 1/8" = 1'-0"

CONSULTANT INFO

DDA ENGINEERS, P.A.
CONSULTING

4930 S.W. 74TH COURT
MIAMI, FLORIDA 33155
PHONE: (305) 666-0711
FAX: (305) 666-6269
WWW.DDAENG.COM
2019-42-A

NEW ELEMENTARY SCHOOL (K-5)
VENETIAN PARC WEST

SOUTHWEST 157th AVENUE and 174th STREET
MIAMI, FL. 33187
MDCPS PROJECT No. 01892600

KEY PLAN

CONSULTANT INFO

ADA M. ALBARRA, P.E.
No. 61101

RODRIGUEZ ARCHITECTS INCORPORATED
2121 PONCE DE LEON BLVD. STE 1010
CORAL GABLES, FL. 33134
TEL: (305) 448-3373
FAX: (305) 448-3374
AAC -- 001933


REVISIONS

NO.	DATE	DESCRIPTION

DRAWING TITLE:
SECOND FLOOR FRAMING PLAN
AREA B

SCALE: AS NOTED

ISSUE DATE: 10.11.19
PROJECT NO. 1906
SHEET: S-224

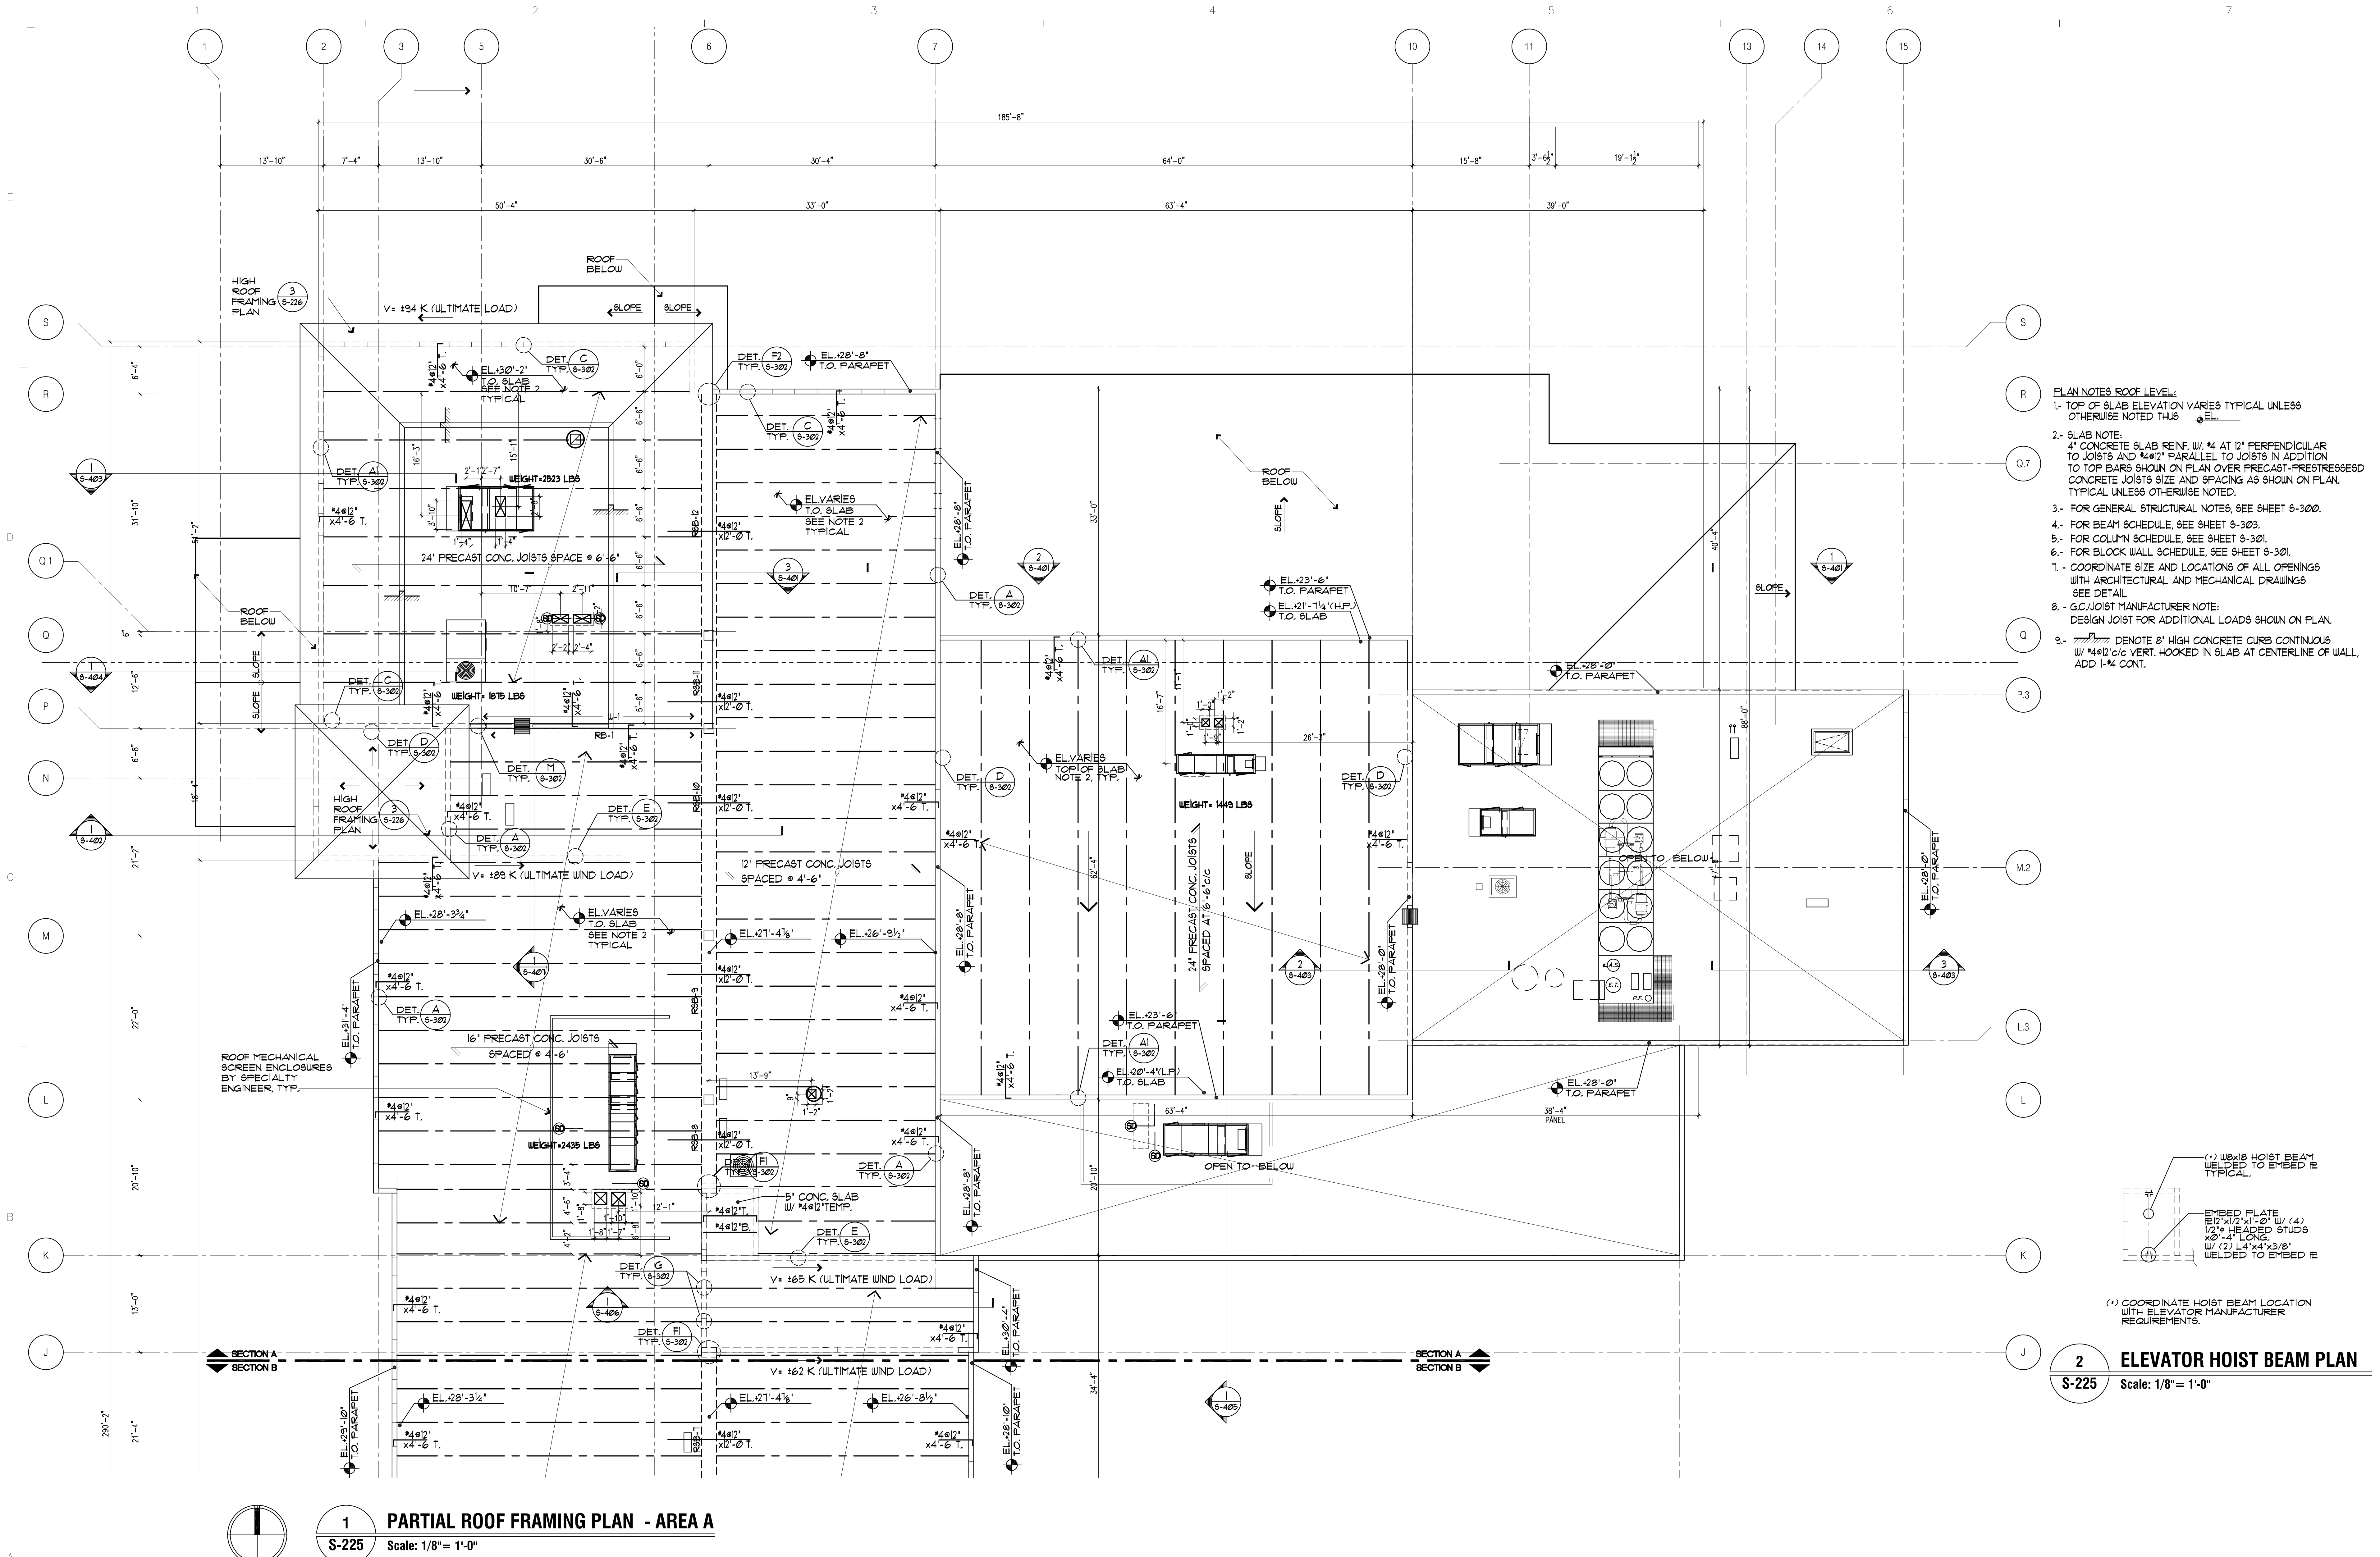

- PLAN NOTES ROOF LEVEL:**
- 1- TOP OF SLAB ELEVATION VARIES TYPICAL UNLESS OTHERWISE NOTED THIS ∇ EL.
 - 2- SLAB NOTE:
4" CONCRETE SLAB REIN. W/ #4 AT 12" PERPENDICULAR TO JOISTS AND #4@12" PARALLEL TO JOISTS IN ADDITION TO TOP BARS SHOWN ON PLAN OVER PRECAST-PRESTRESSED CONCRETE JOISTS SIZE AND SPACING AS SHOWN ON PLAN. TYPICAL UNLESS OTHERWISE NOTED.
 - 3- FOR GENERAL STRUCTURAL NOTES, SEE SHEET S-300.
 - 4- FOR BEAM SCHEDULE, SEE SHEET S-303.
 - 5- FOR COLUMN SCHEDULE, SEE SHEET S-301.
 - 6- FOR BLOCK WALL SCHEDULE, SEE SHEET S-301.
 - 7- COORDINATE SIZE AND LOCATIONS OF ALL OPENINGS WITH ARCHITECTURAL AND MECHANICAL DRAWINGS. SEE DETAIL.
 - 8- G.C./JOIST MANUFACTURER NOTE:
DESIGN JOIST FOR ADDITIONAL LOADS SHOWN ON PLAN.
 - 9- ∇ DENOTE 8" HIGH CONCRETE CURB CONTINUOUS W/ #4@12" c/c VERT. HOOKED IN SLAB AT CENTERLINE OF WALL, ADD 1-#4 CONT.

2 ELEVATOR HOIST BEAM PLAN
S-225 Scale: 1/8" = 1'-0"

1 PARTIAL ROOF FRAMING PLAN - AREA A
S-225 Scale: 1/8" = 1'-0"

CONSULTANT INFO

DDA ENGINEERS, P.A.
CONSULTING

4930 S.W. 74TH COURT
MIAMI, FLORIDA 33155
PHONE: (305) 666-0711
FAX: (305) 666-6269
WWW.DDAENG.COM
2019-42-A

NEW ELEMENTARY SCHOOL (K-5)
VENETIAN PARC WEST
SOUTHWEST 157th AVENUE and 174th STREET
MIAMI, FL. 33187
MDCPS PROJECT No. 01892600

KEY PLAN

CONSULTANT INFO

ADA M. ALBARRA P.E.
NO. 61300

RODRIGUEZ ARCHITECTS INCORPORATED

2121 PONCE DE LEON BLVD. STE 1010
CORAL GABLES, FL. 33134
TEL: (305) 448-3373
FAX: (305) 448-3374
AAC -- 001933



REVISIONS

NO.	DESCRIPTION	DATE


DRAWING TITLE: **ROOF FRAMING PLAN AREA A**

SCALE: AS NOTED


ISSUE DATE: 10.11.19
PROJECT NO: 1906
SHEET: **S-225**

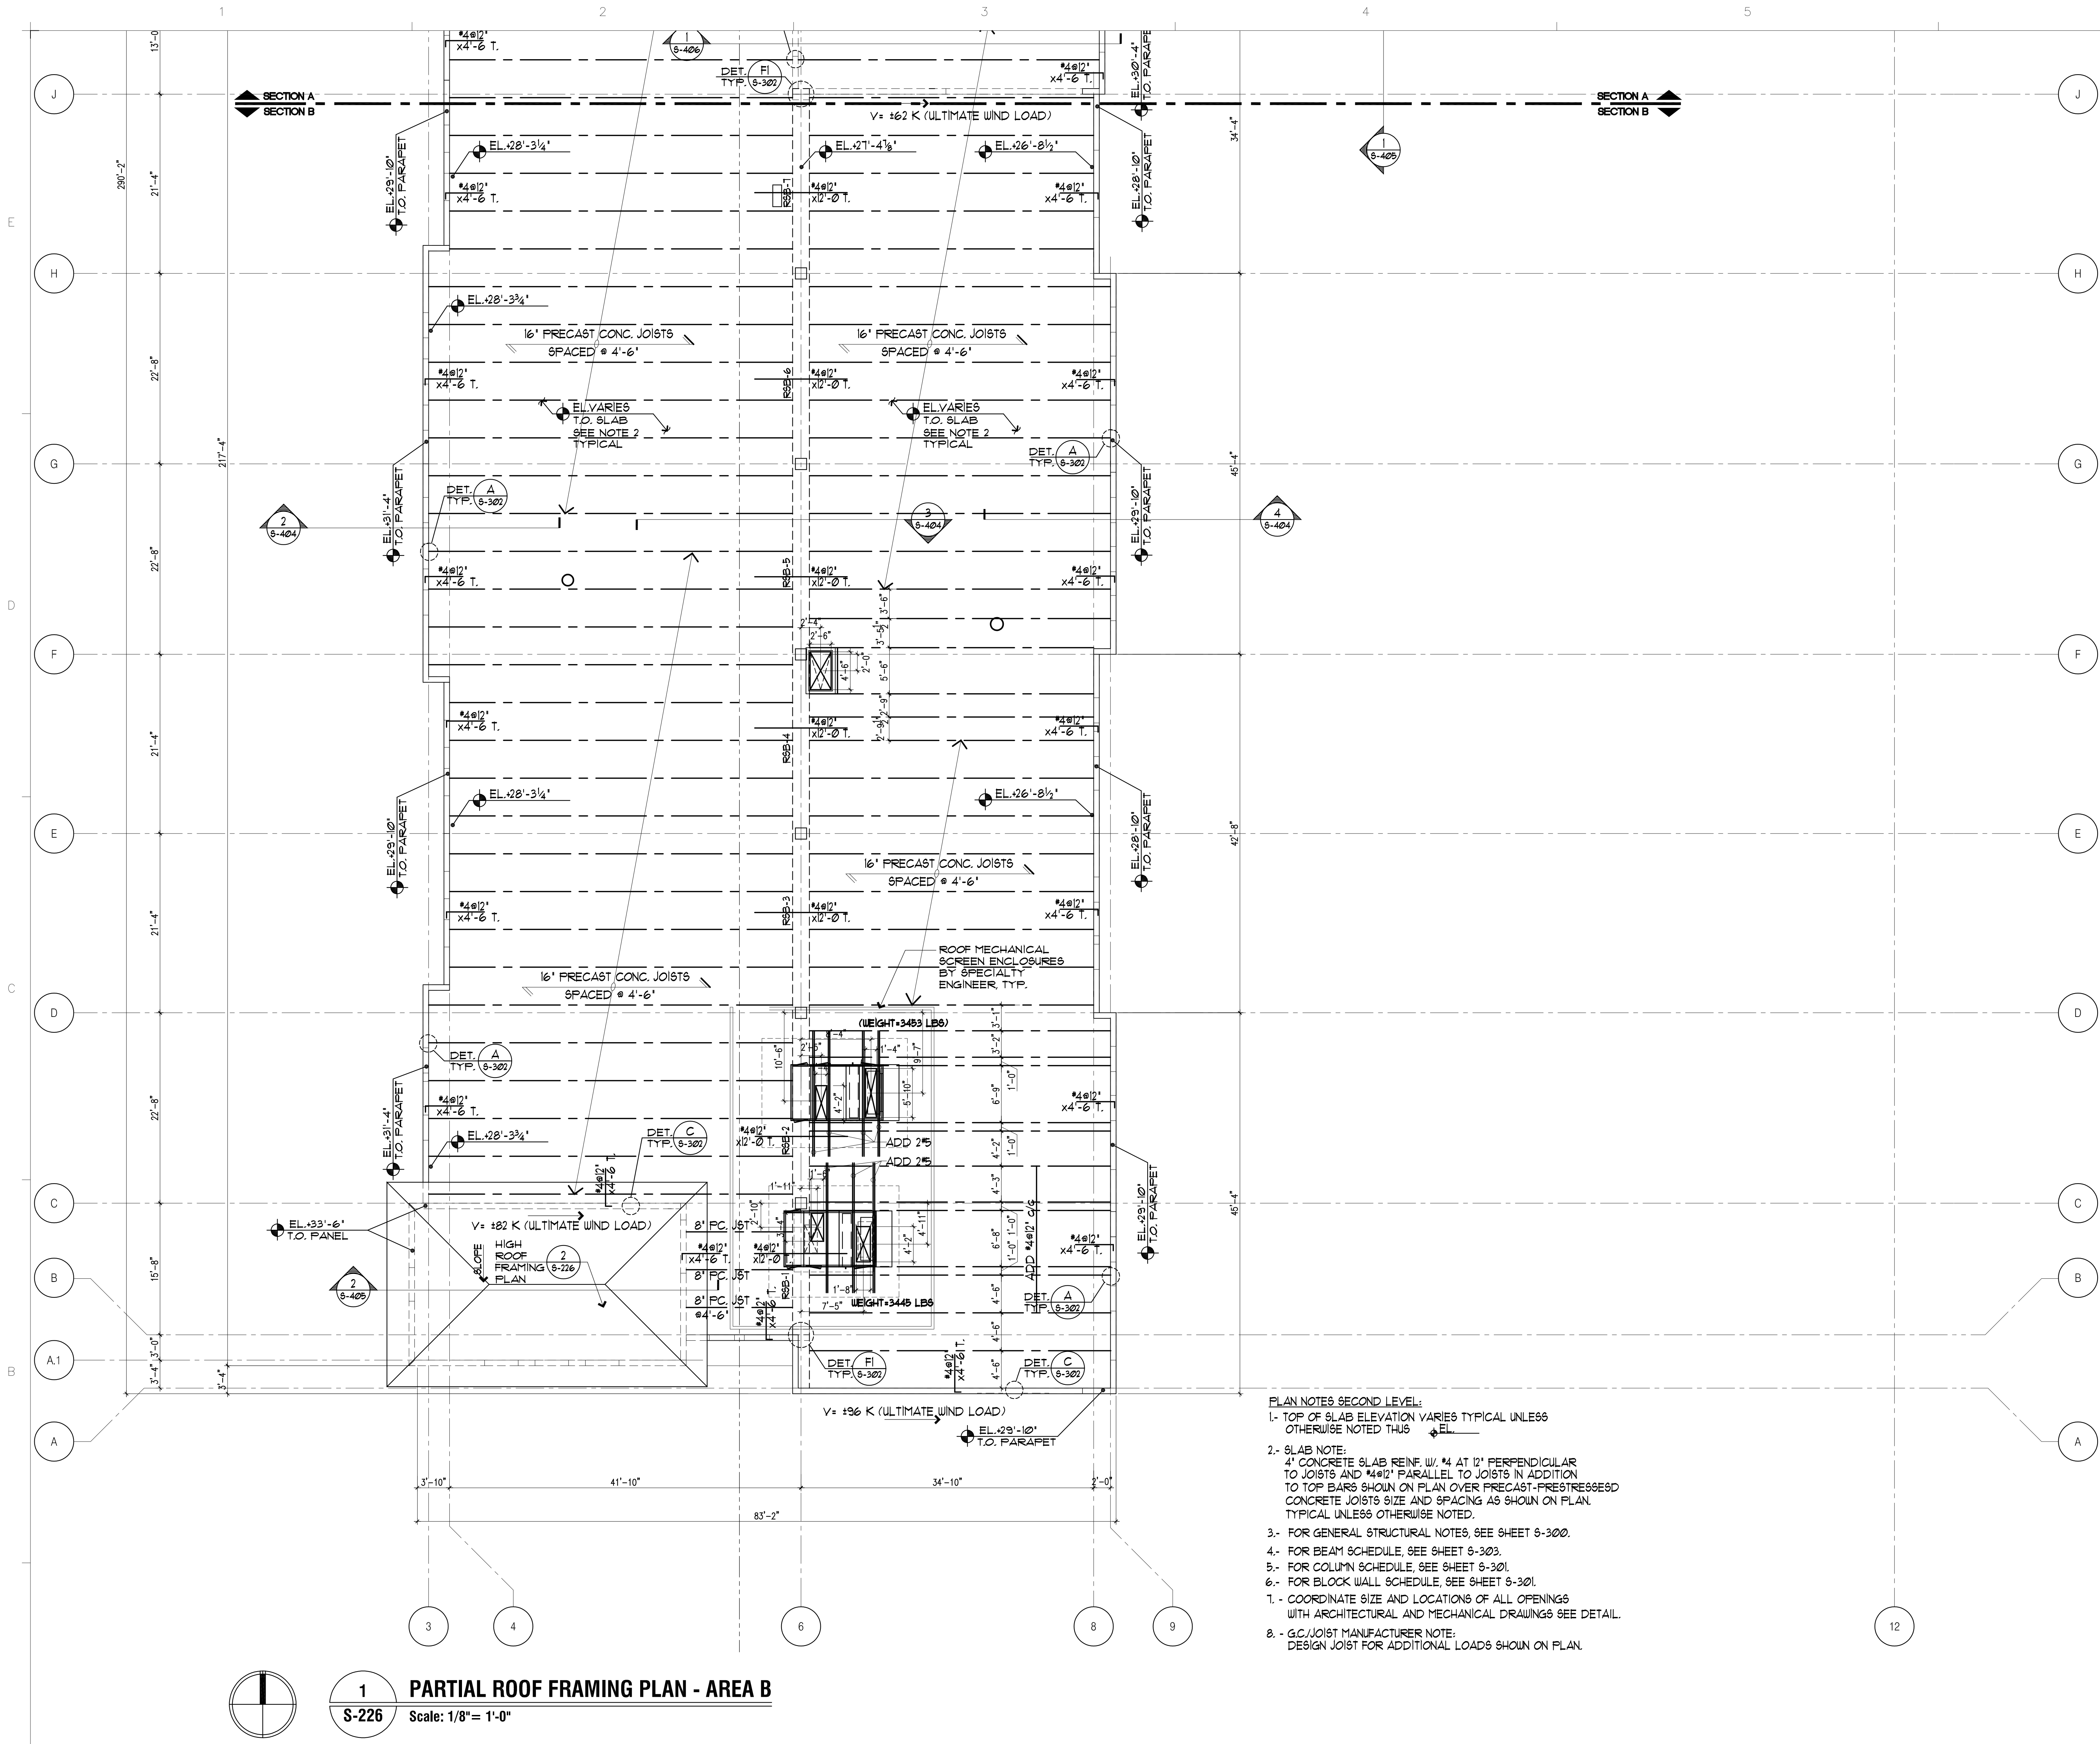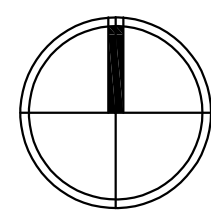


1 PARTIAL ROOF FRAMING PLAN - AREA B
S-226 Scale: 1/8" = 1'-0"

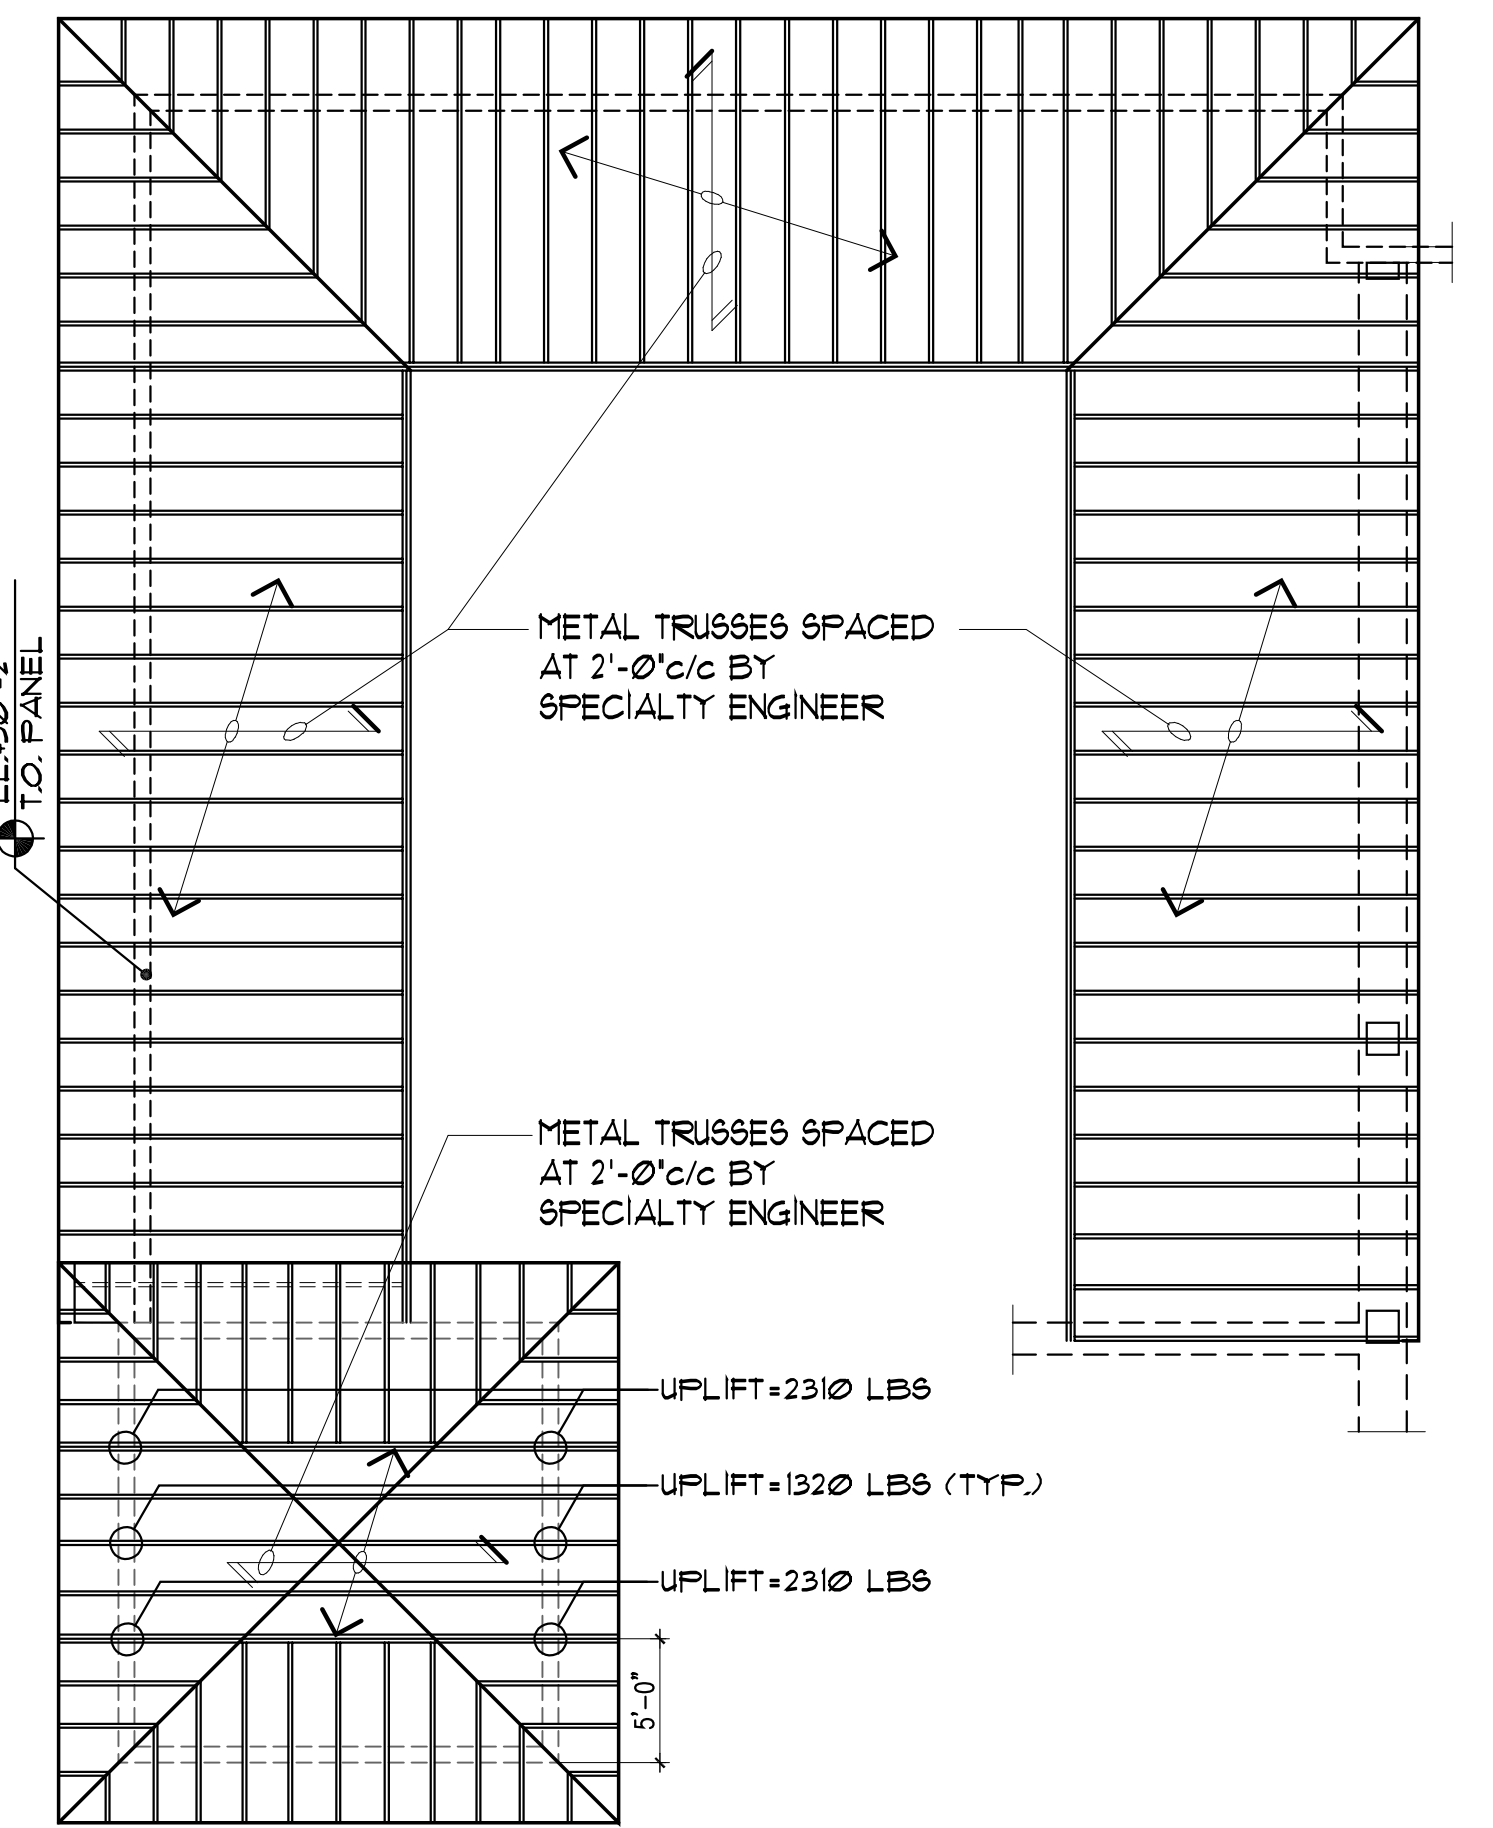


3 HIGH ROOF FRAMING PLAN
S-226 Scale: 1/8" = 1'-0"
1- 1 1/2" GALV. METAL DECK 22 GA. TYPE B SUPPORTED ON STEEL TRUSSES SPACED AS SHOWN ON PLAN. DECKS TO BE CONNECTED TO STEEL SUPPORT WITH NO 12 TEK SCREWS. PATTERN TO BE 36/1 AT END SUPPORTS AND 36/1 AT INTERIOR SUPPORT WITH (5) FIVE STITCH CONNECTORS AT SIDE LAPS (NO 10 SCREWS) PROVIDE NO 12 TEK SCREWS AT 6' c/c AT EDGE SUPPORT. TYPICAL UNLESS OTHERWISE NOTED ON PLAN.
METAL DECK SHALL BE ASTM A-653 GRADE 33" Fu = 45 KSI. MINIMUM THICK = 0.235 IN. MIN. Lx = 0.183 IN4. MIN. Sx = 0.182 IN3.

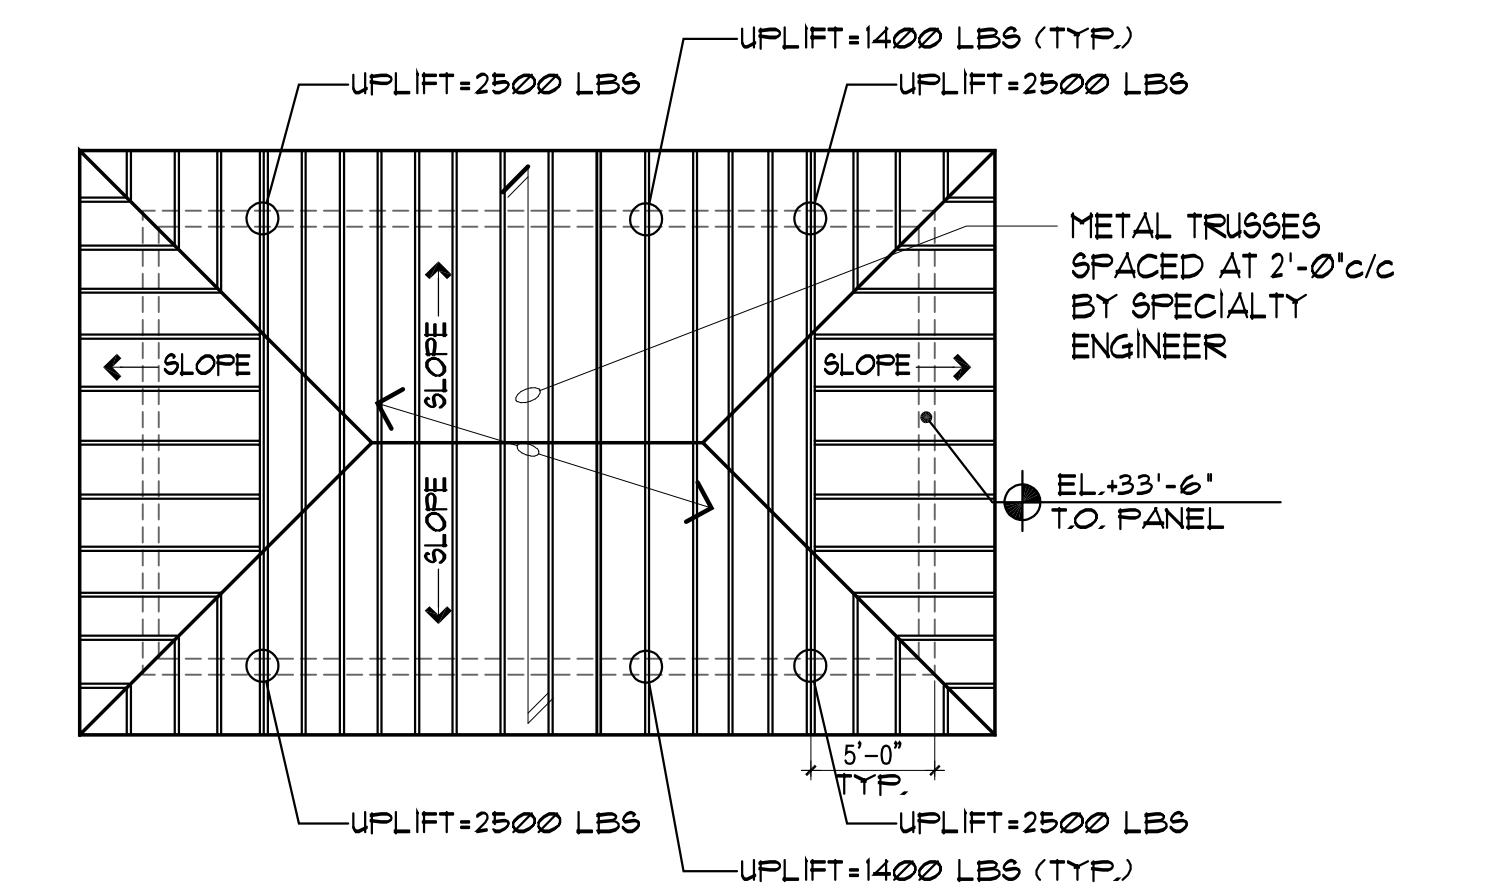


2 HIGH ROOF FRAMING PLAN
S-226 Scale: 1/8" = 1'-0"
1- 1 1/2" GALV. METAL DECK 22 GA. TYPE B SUPPORTED ON STEEL TRUSSES SPACED AS SHOWN ON PLAN. DECKS TO BE CONNECTED TO STEEL SUPPORT WITH NO 12 TEK SCREWS. PATTERN TO BE 36/1 AT END SUPPORTS AND 36/1 AT INTERIOR SUPPORT WITH (5) FIVE STITCH CONNECTORS AT SIDE LAPS (NO 10 SCREWS) PROVIDE NO 12 TEK SCREWS AT 6' c/c AT EDGE SUPPORT. TYPICAL UNLESS OTHERWISE NOTED ON PLAN.
METAL DECK SHALL BE ASTM A-653 GRADE 33" Fu = 45 KSI. MINIMUM THICK = 0.235 IN. MIN. Lx = 0.183 IN4. MIN. Sx = 0.182 IN3.

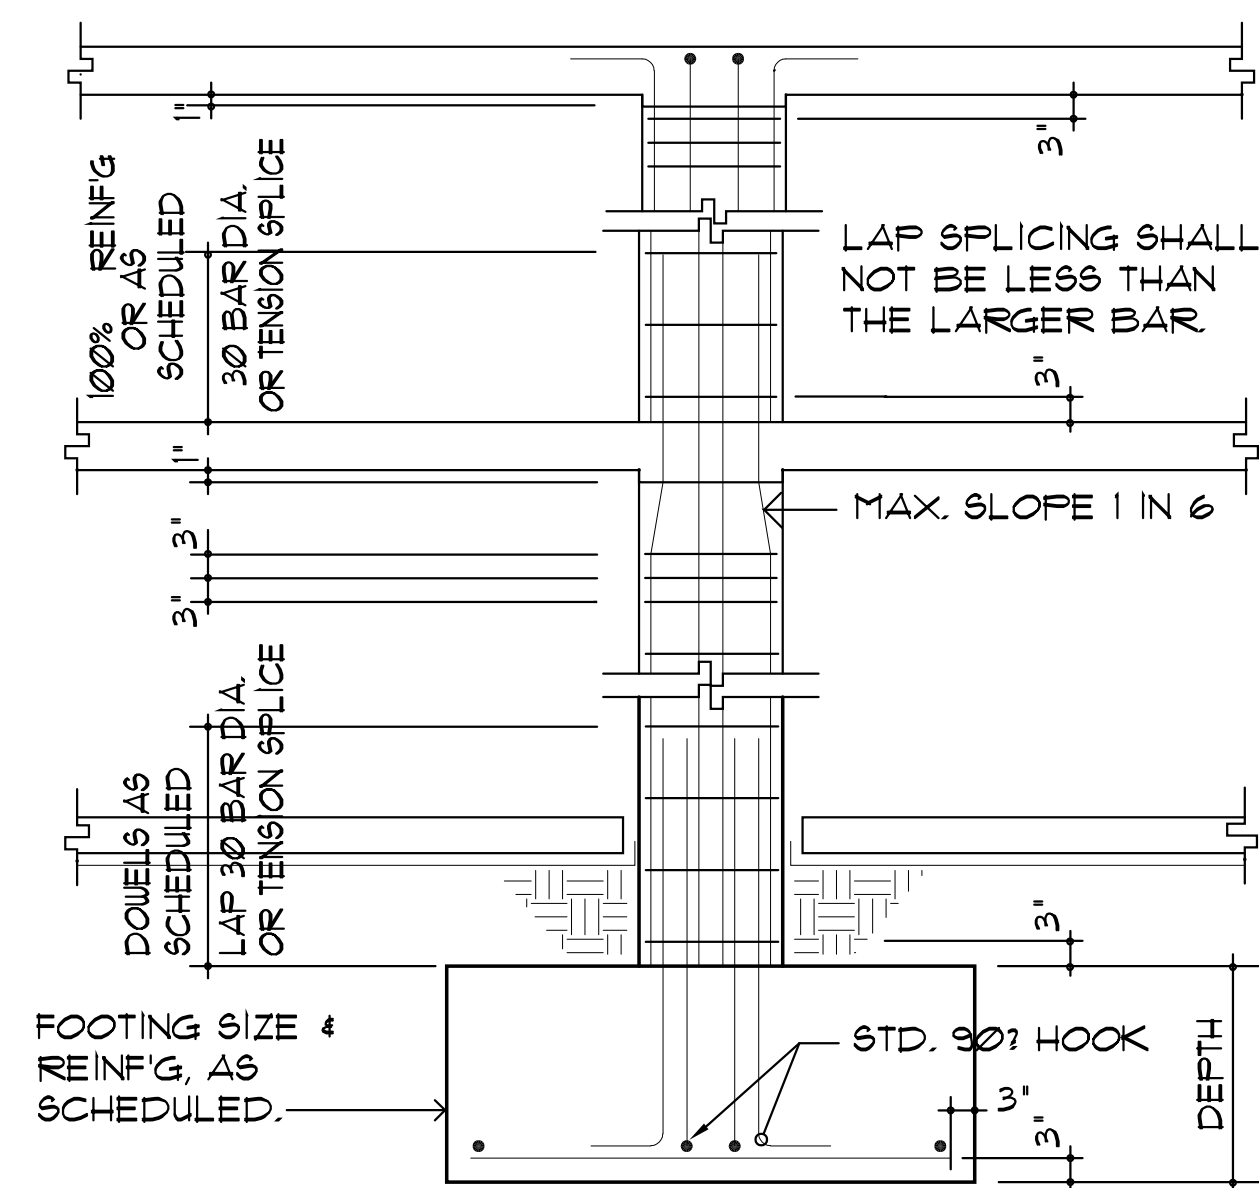


A TYPICAL CONCRETE COLUMN DETAIL
 8-301 SCALE: N.T.S.

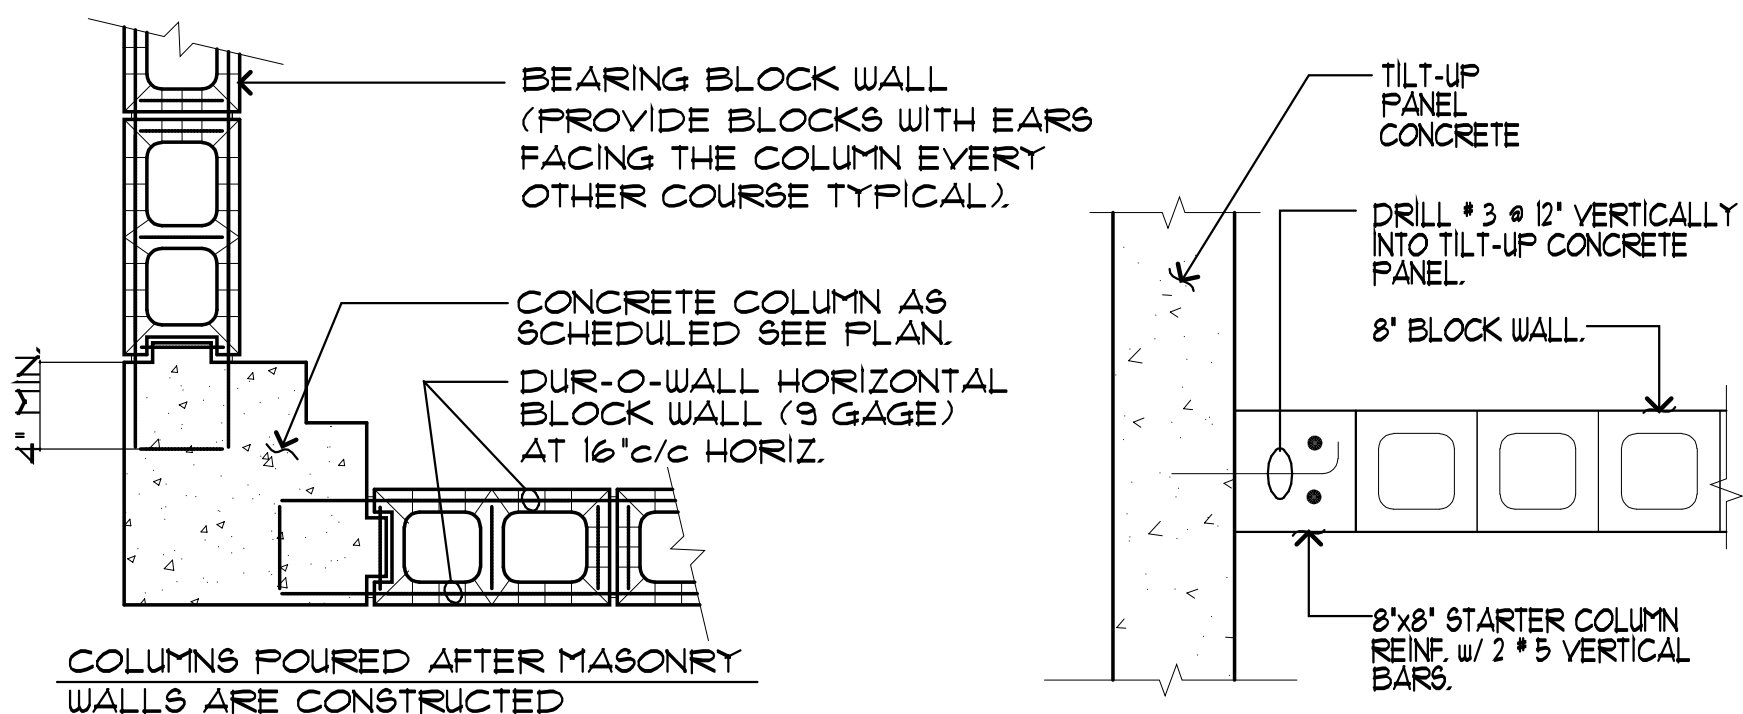

E DETAIL
 8-301 SCALE: 1/2"=1'-0"

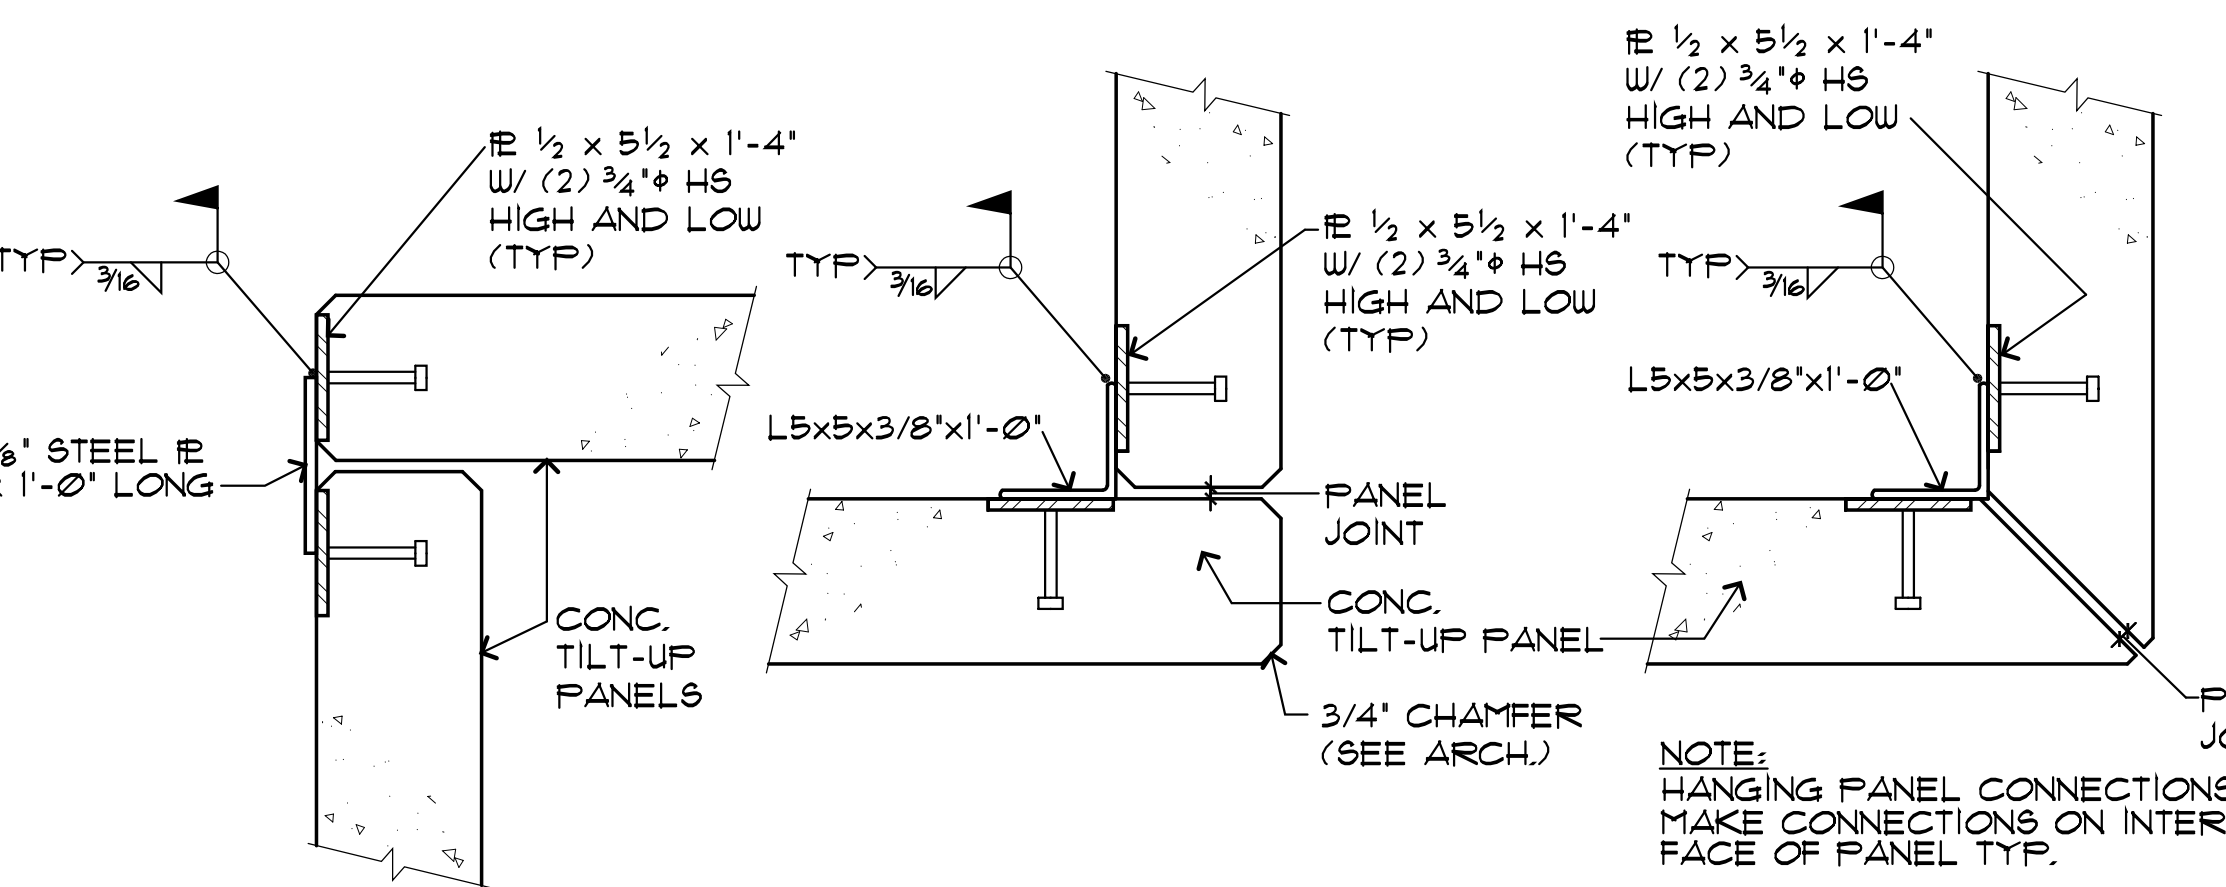


L DETAIL
 8-301 NO SCALE

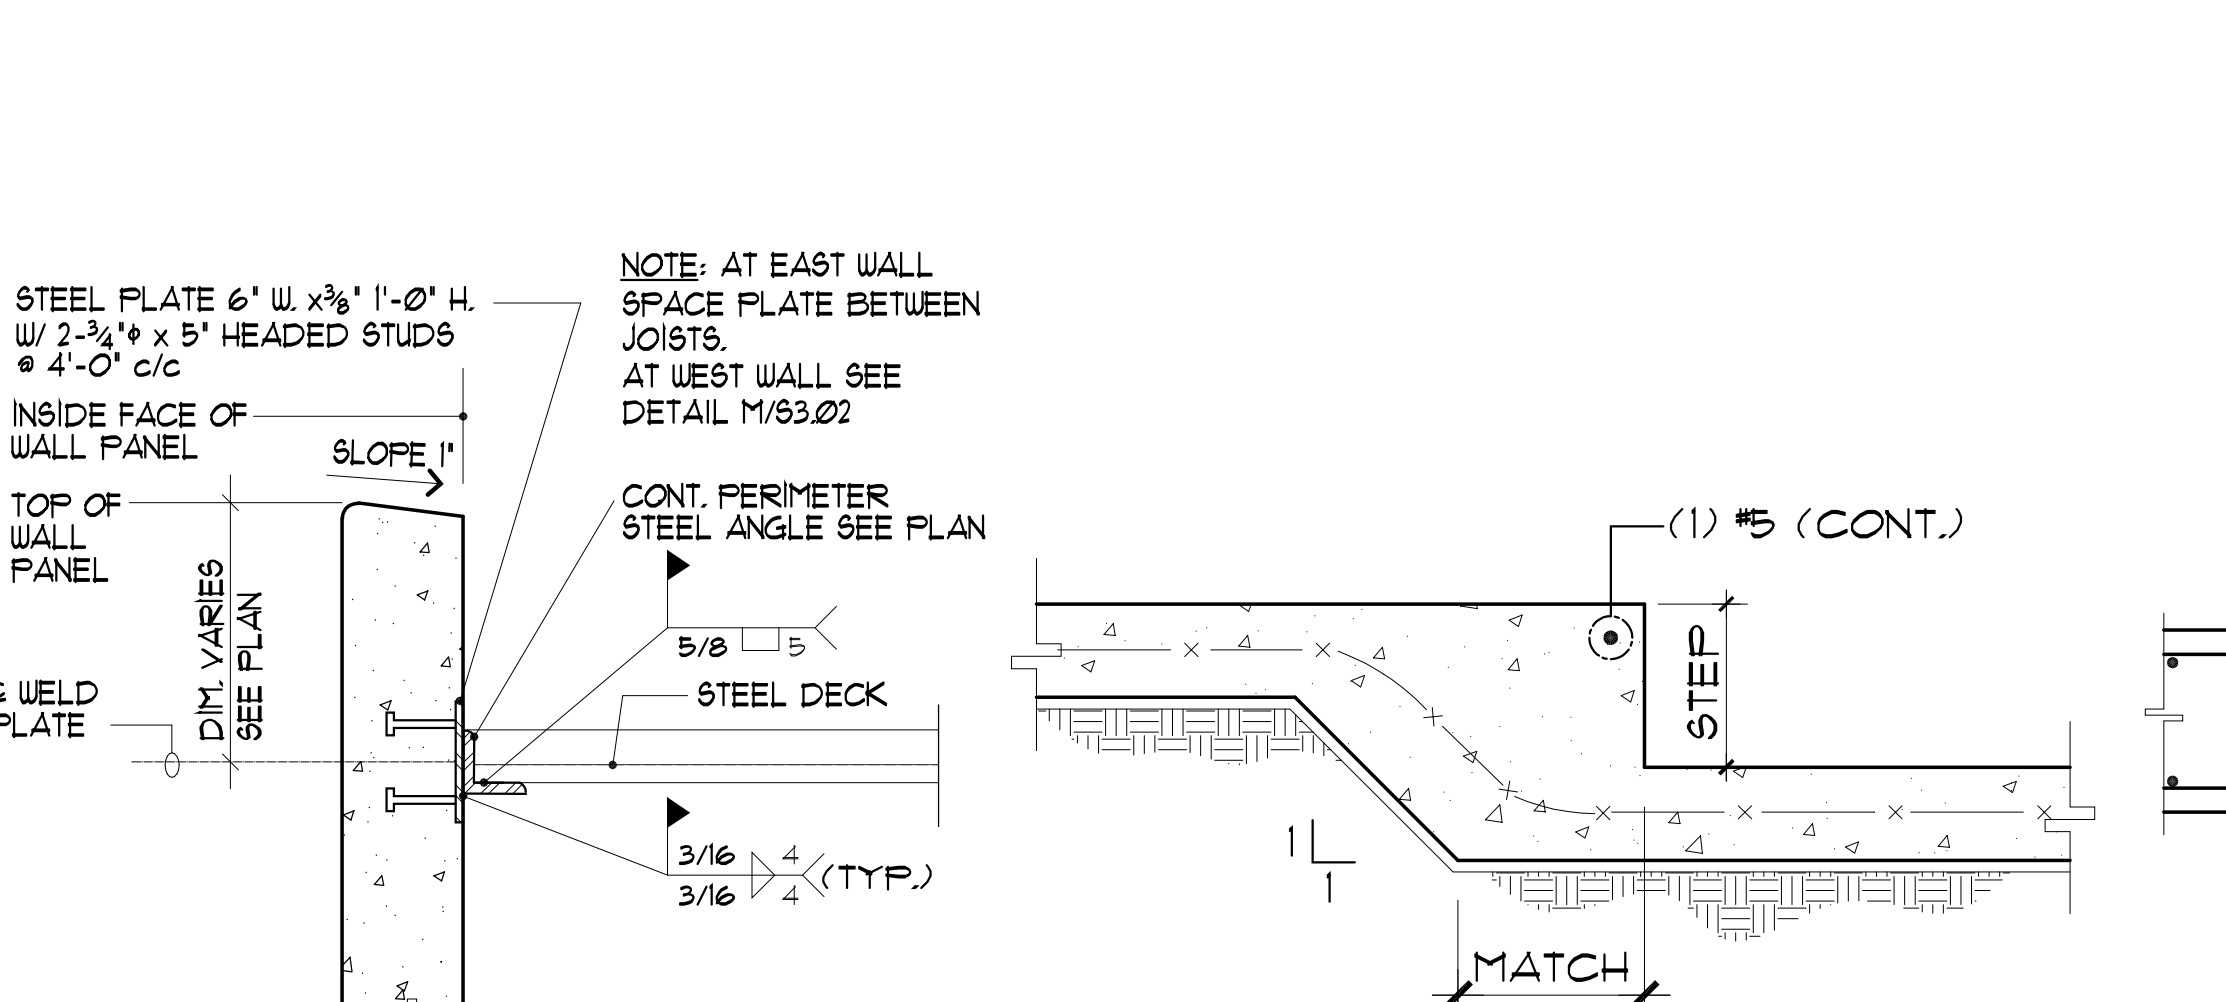


P DETAIL
 8-301 NO SCALE




Q DETAIL
 8-301 NO SCALE

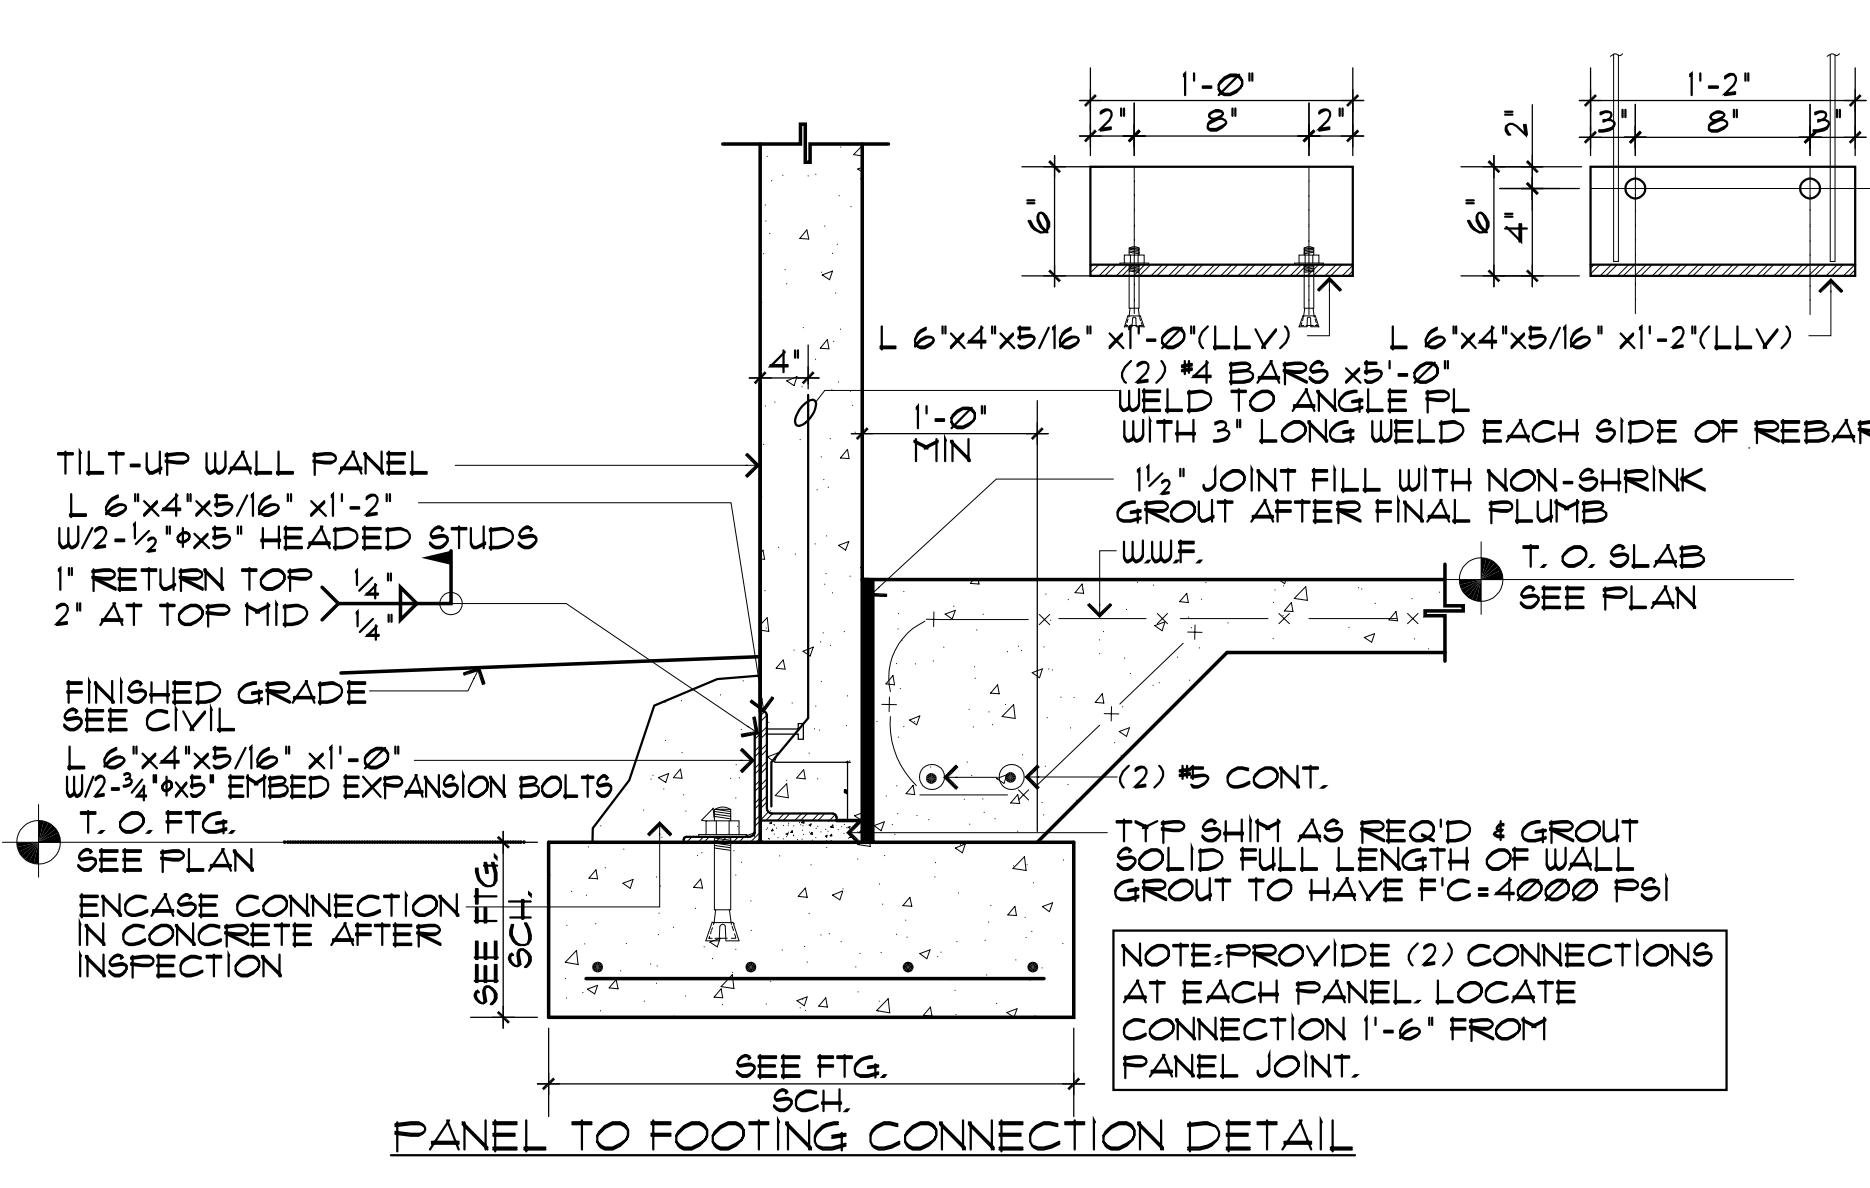


B DETAIL
 8-301 NO SCALE

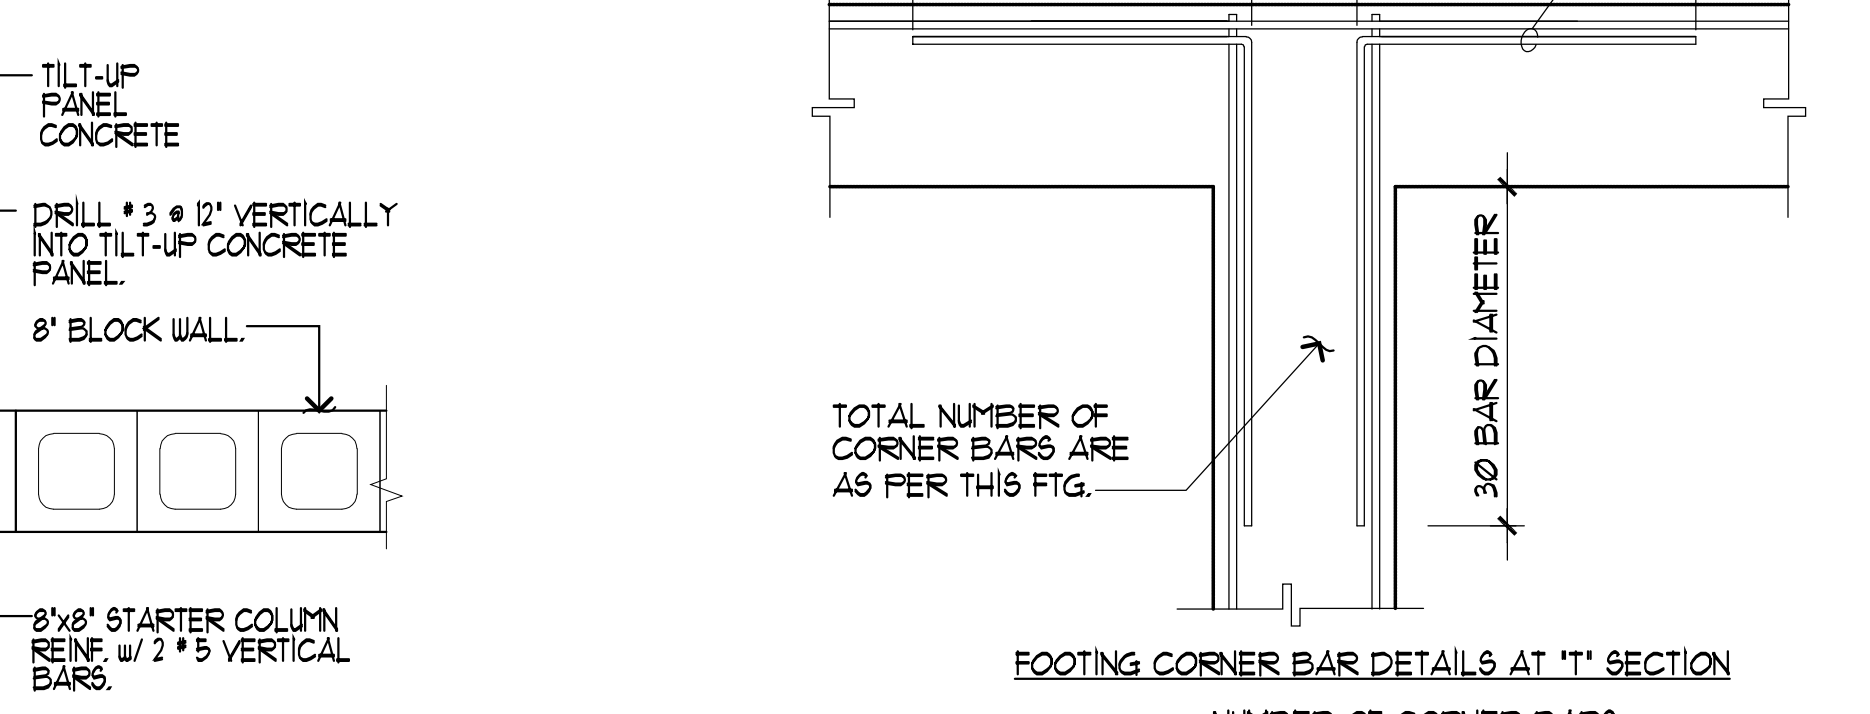


C DETAIL
 8-301 NO SCALE

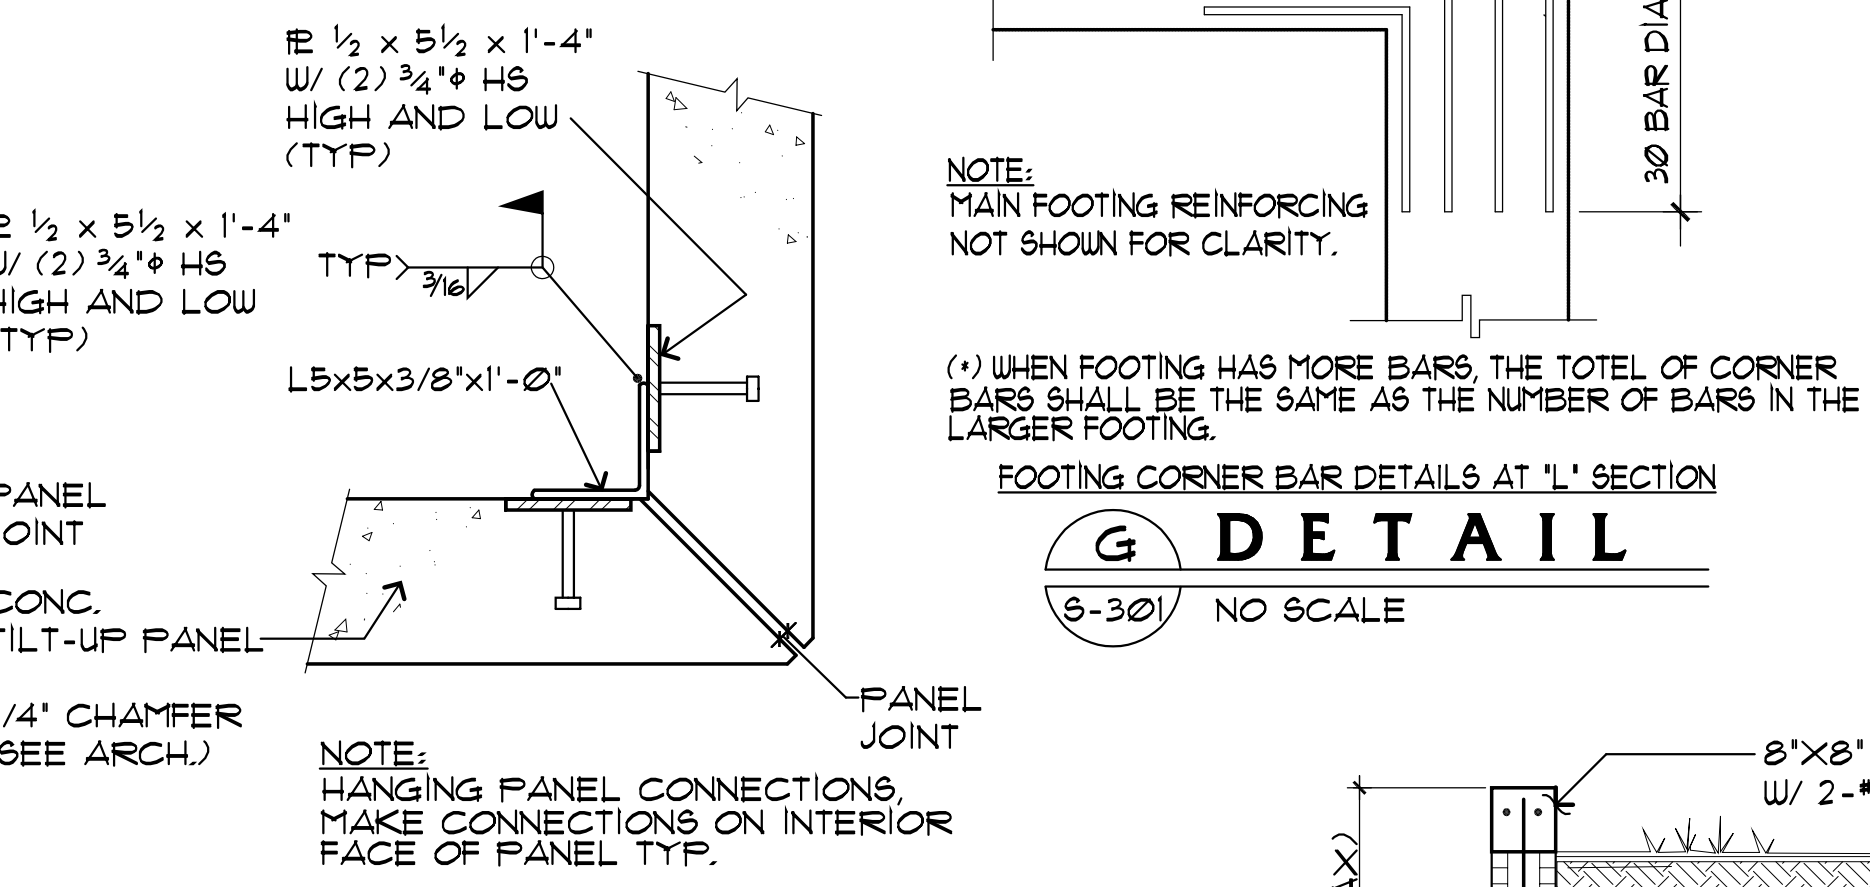


G DETAIL
 8-301 NO SCALE

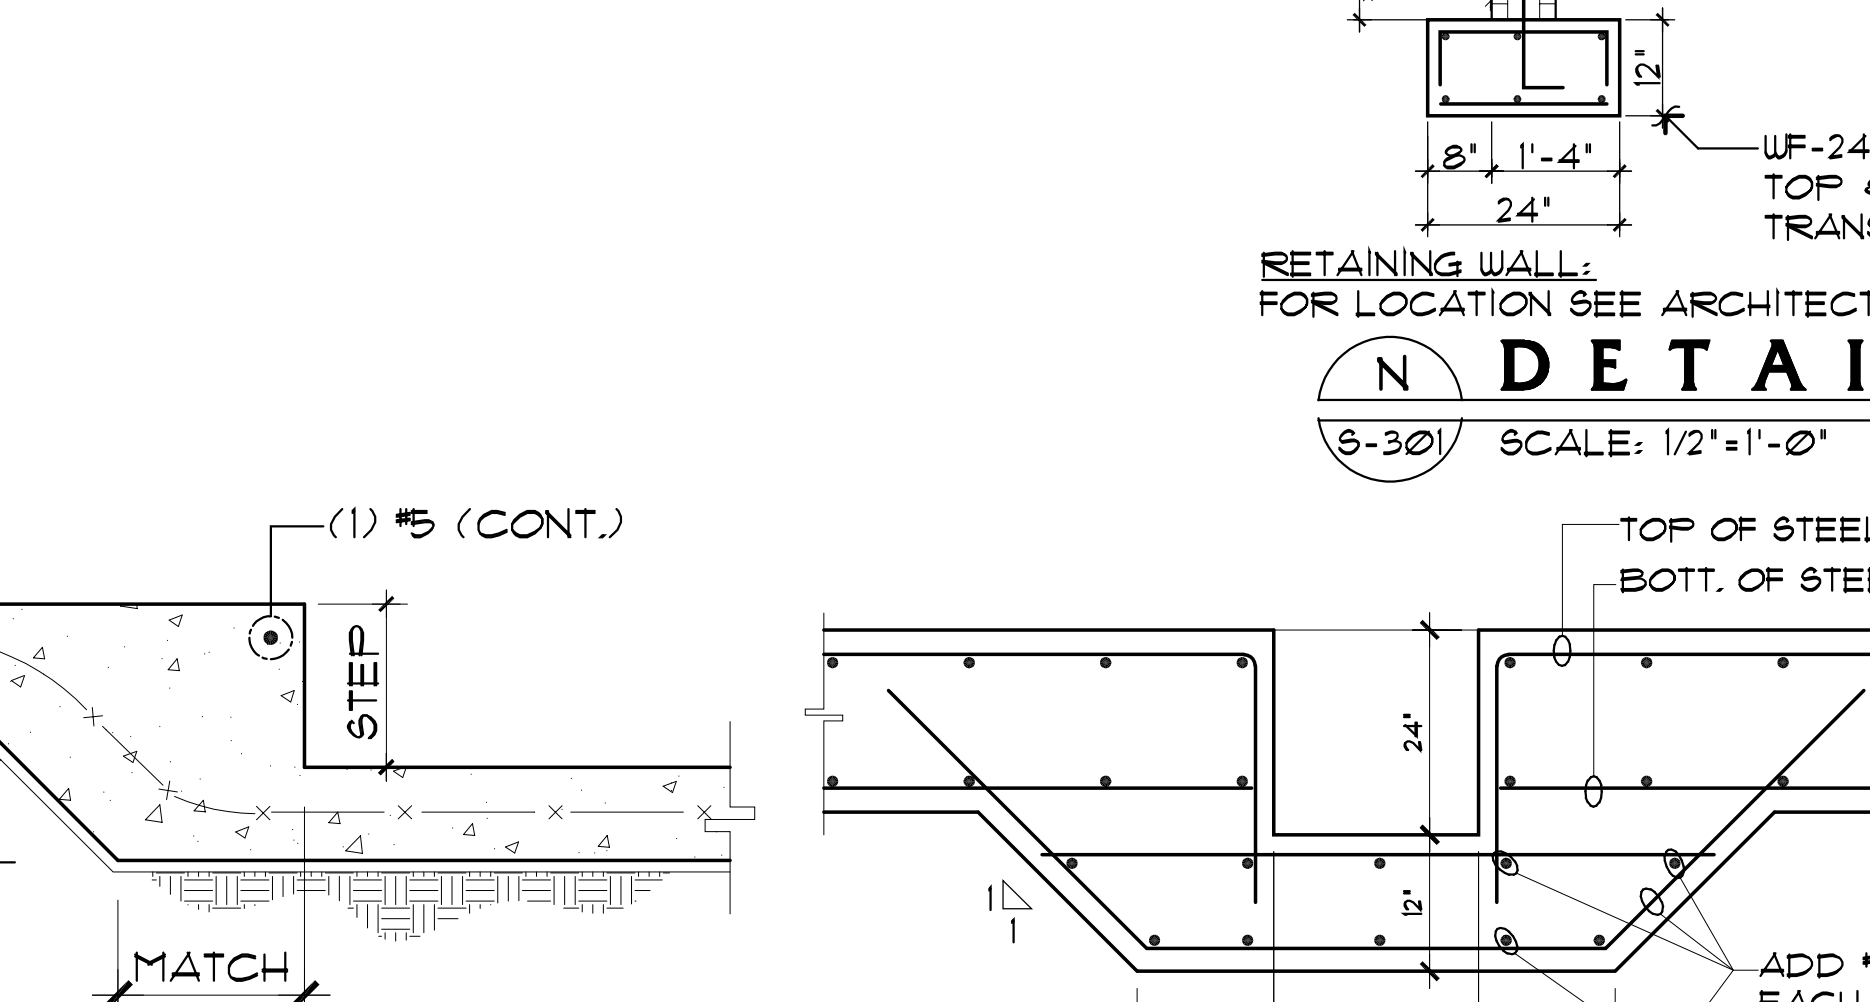


H DETAIL
 8-301 NO SCALE

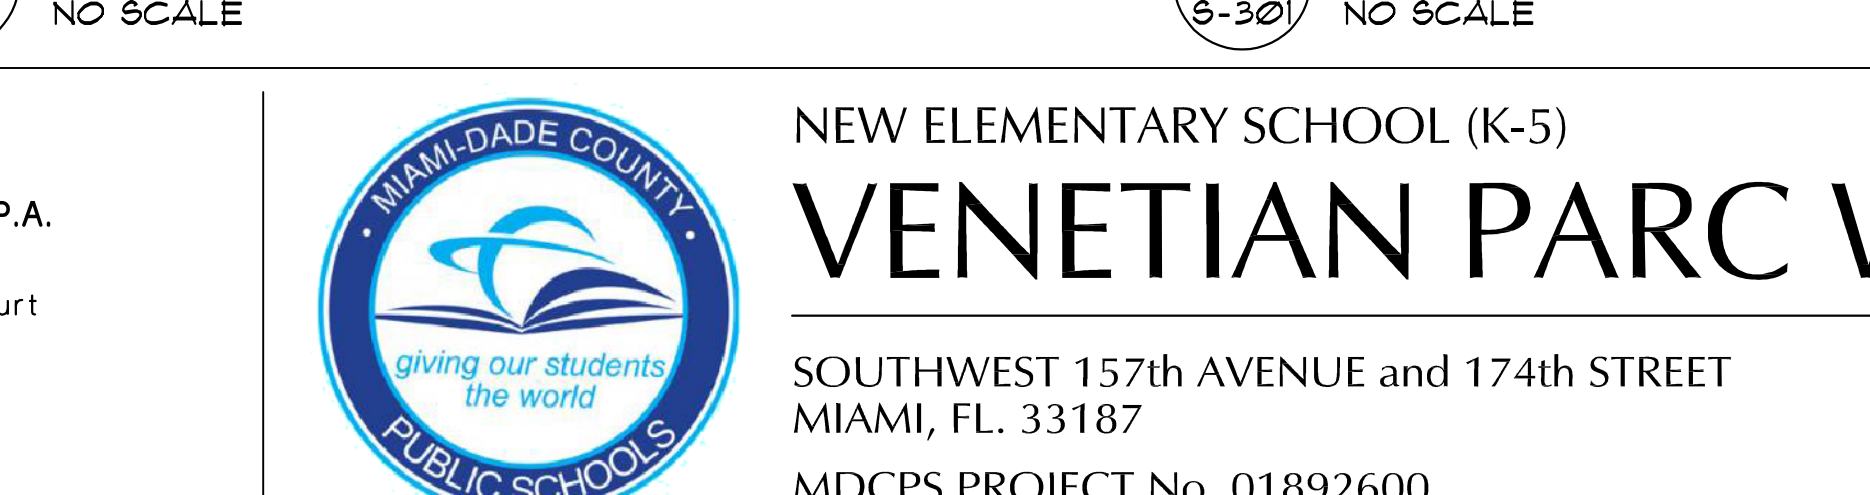


J DETAIL
 8-301 NO SCALE

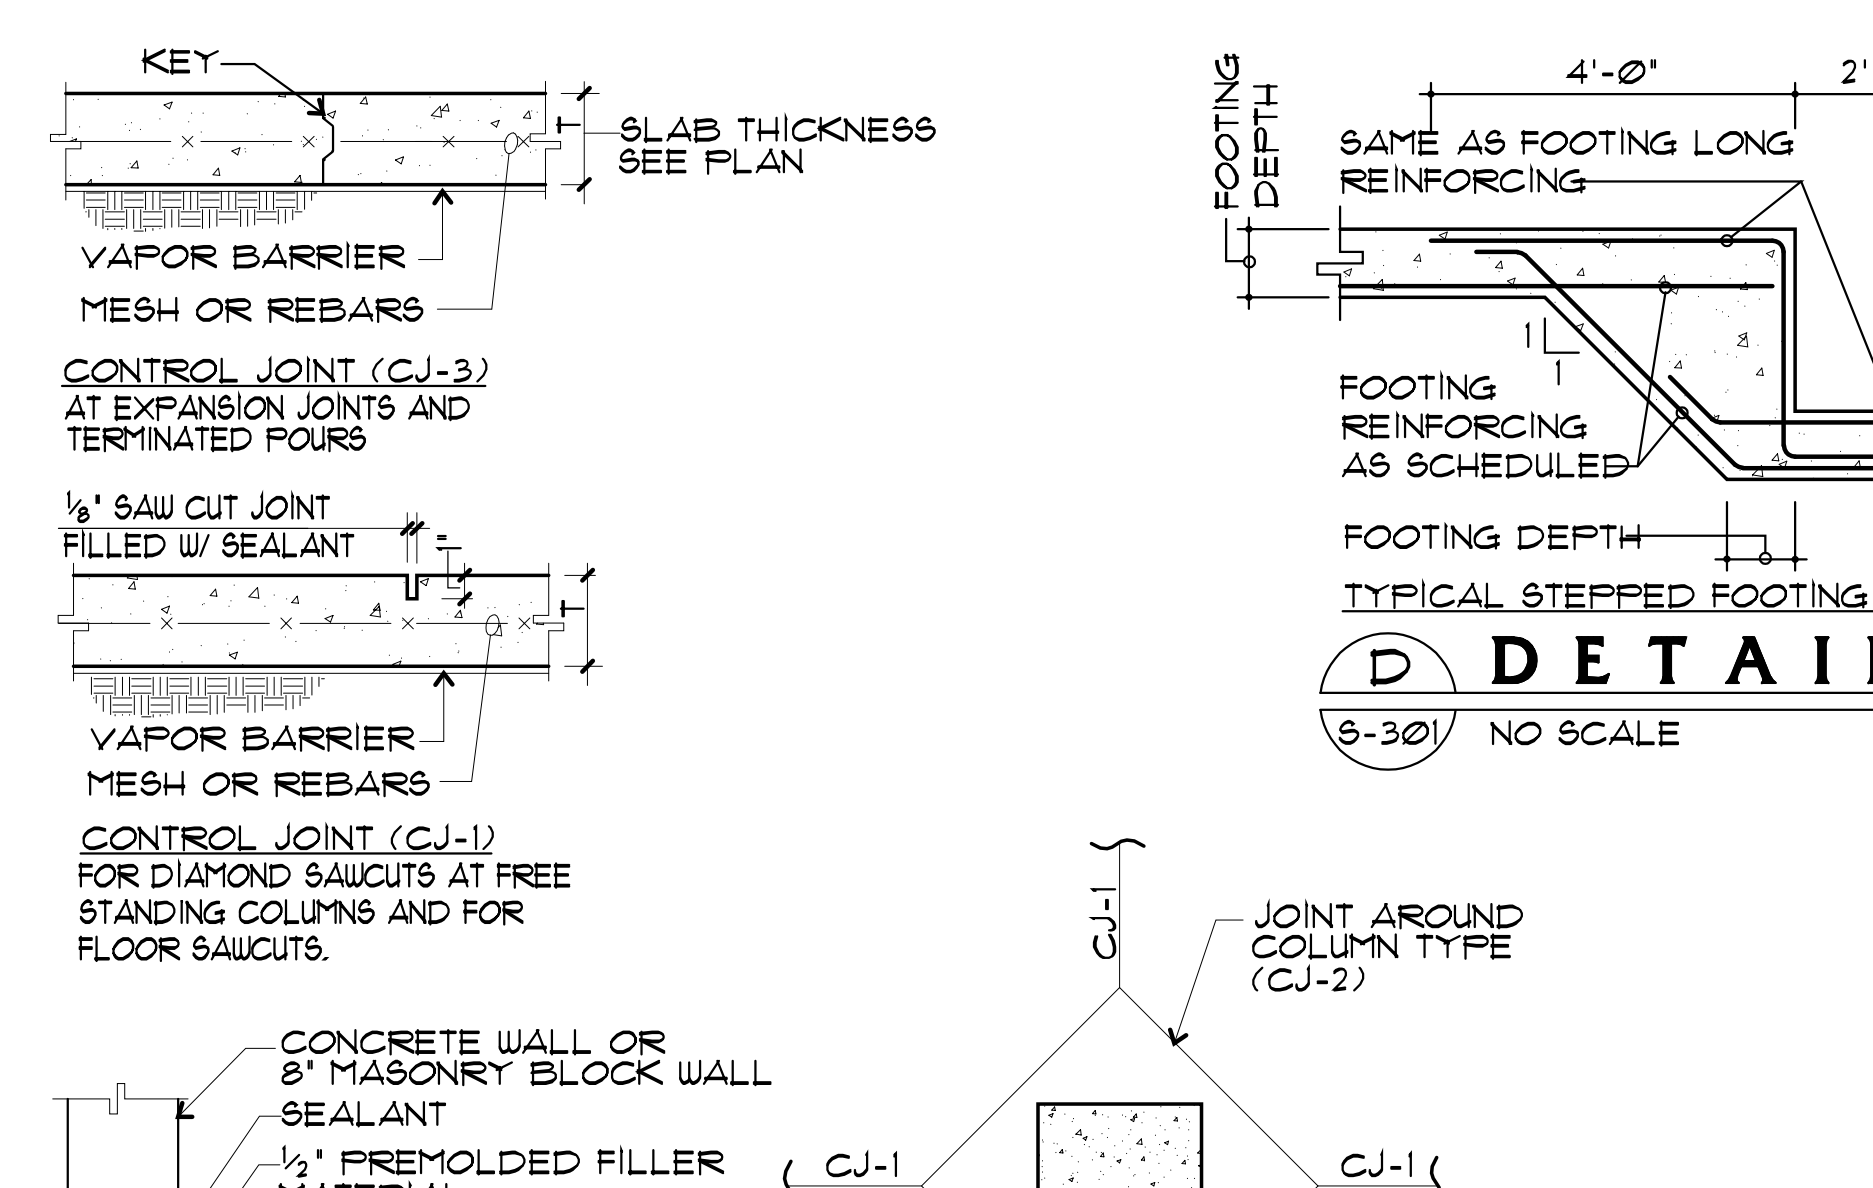


D DETAIL
 8-301 NO SCALE

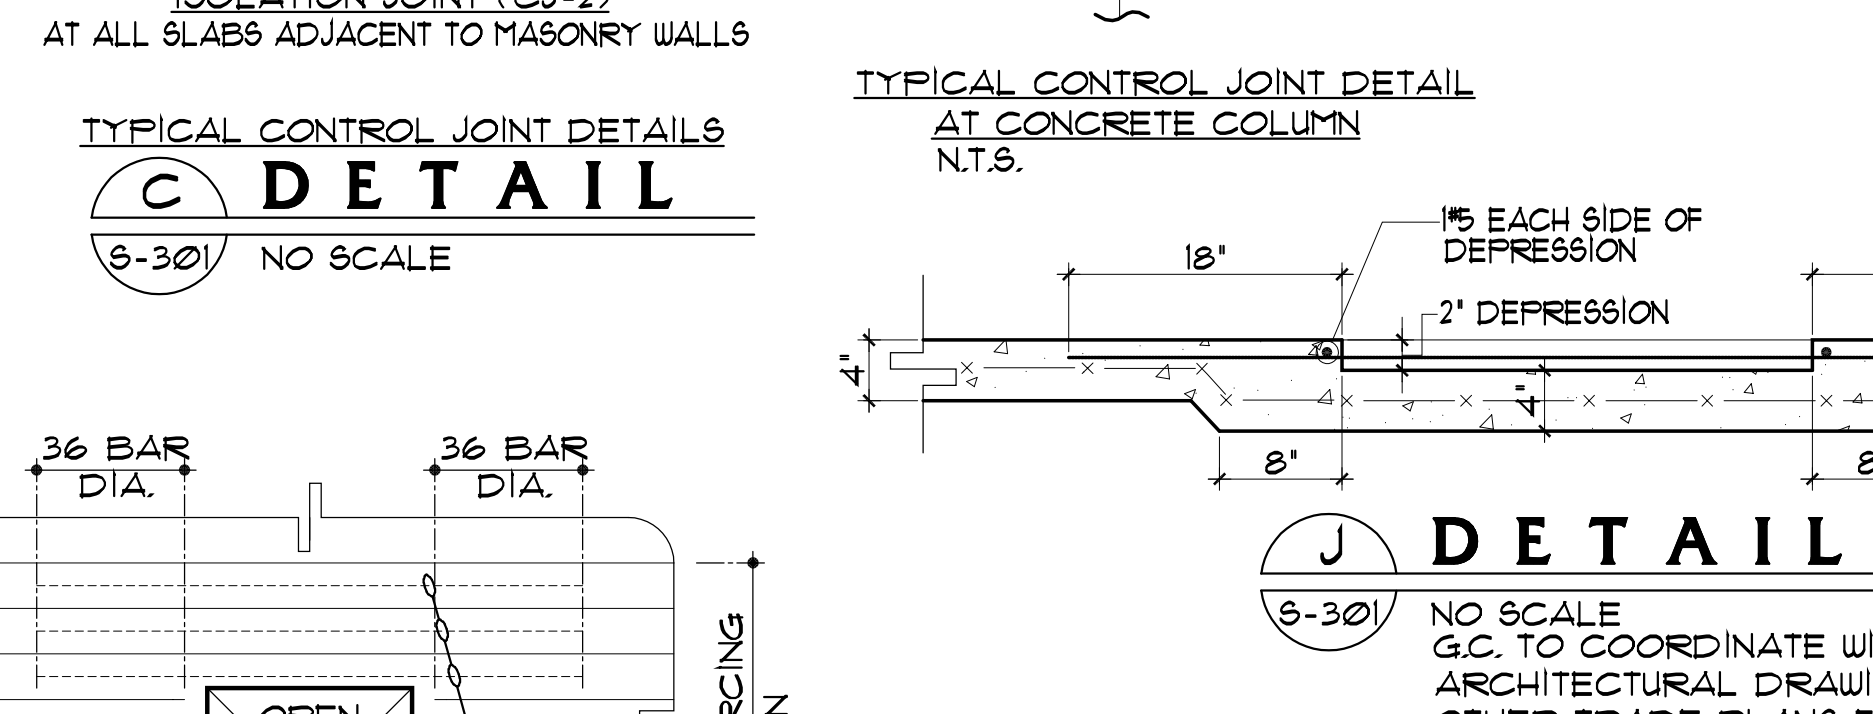


I DETAIL
 8-301 NO SCALE

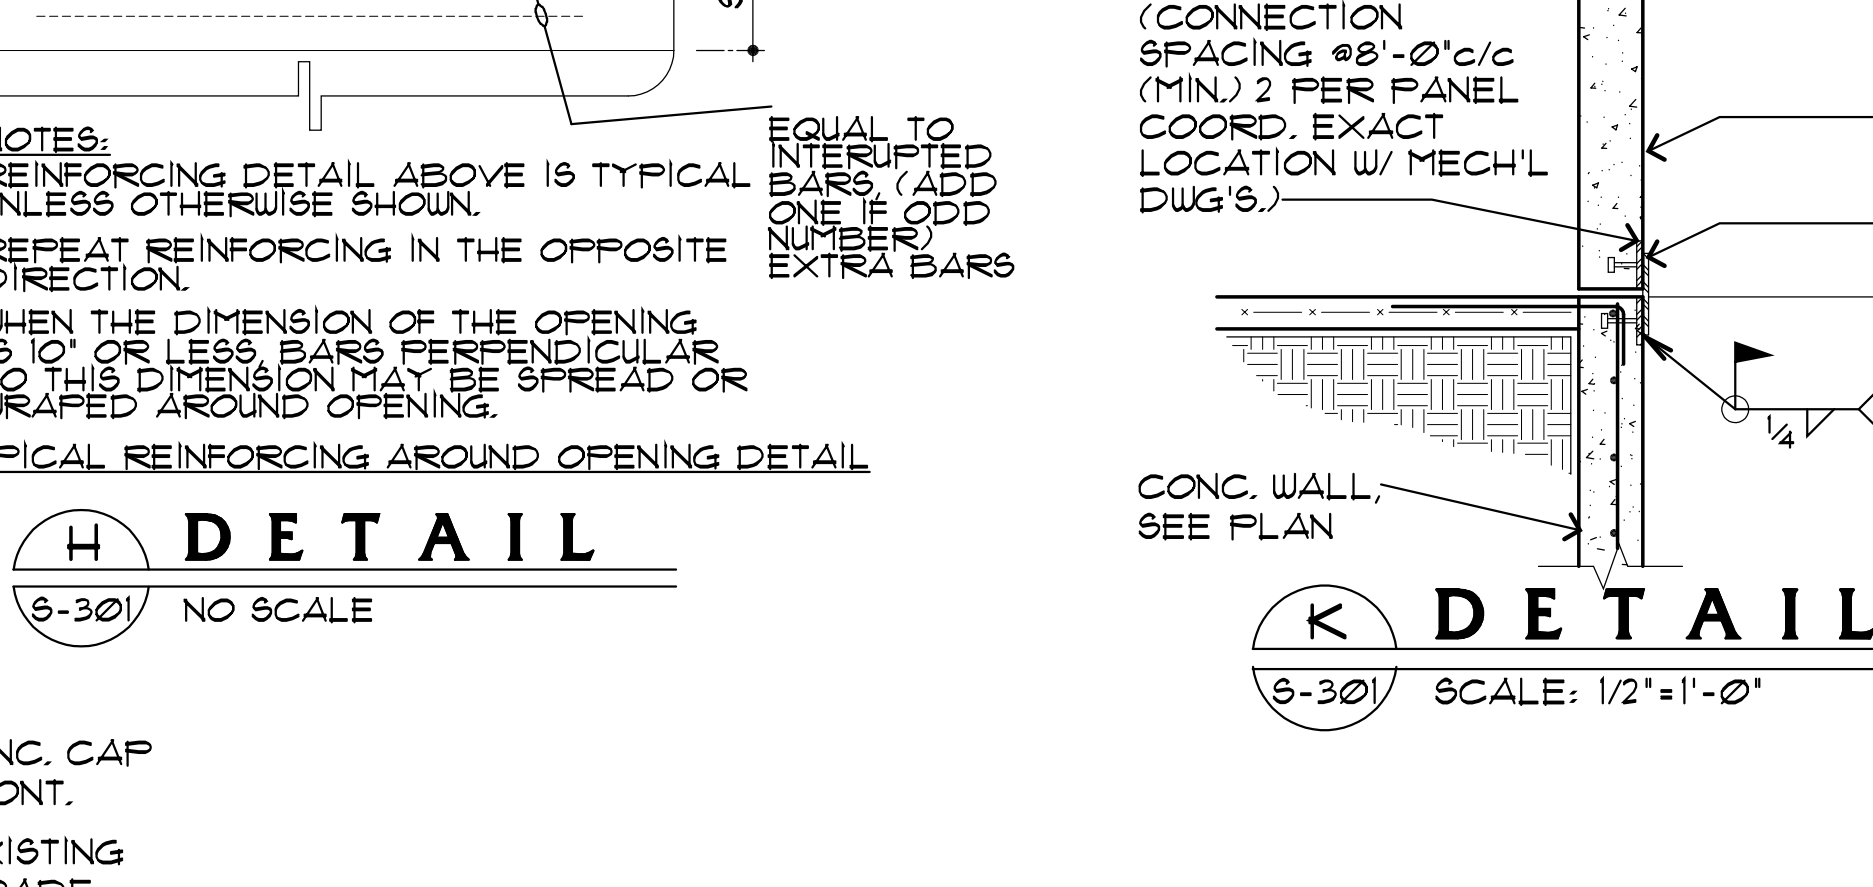


K DETAIL
 8-301 SCALE: 1/2"=1'-0"

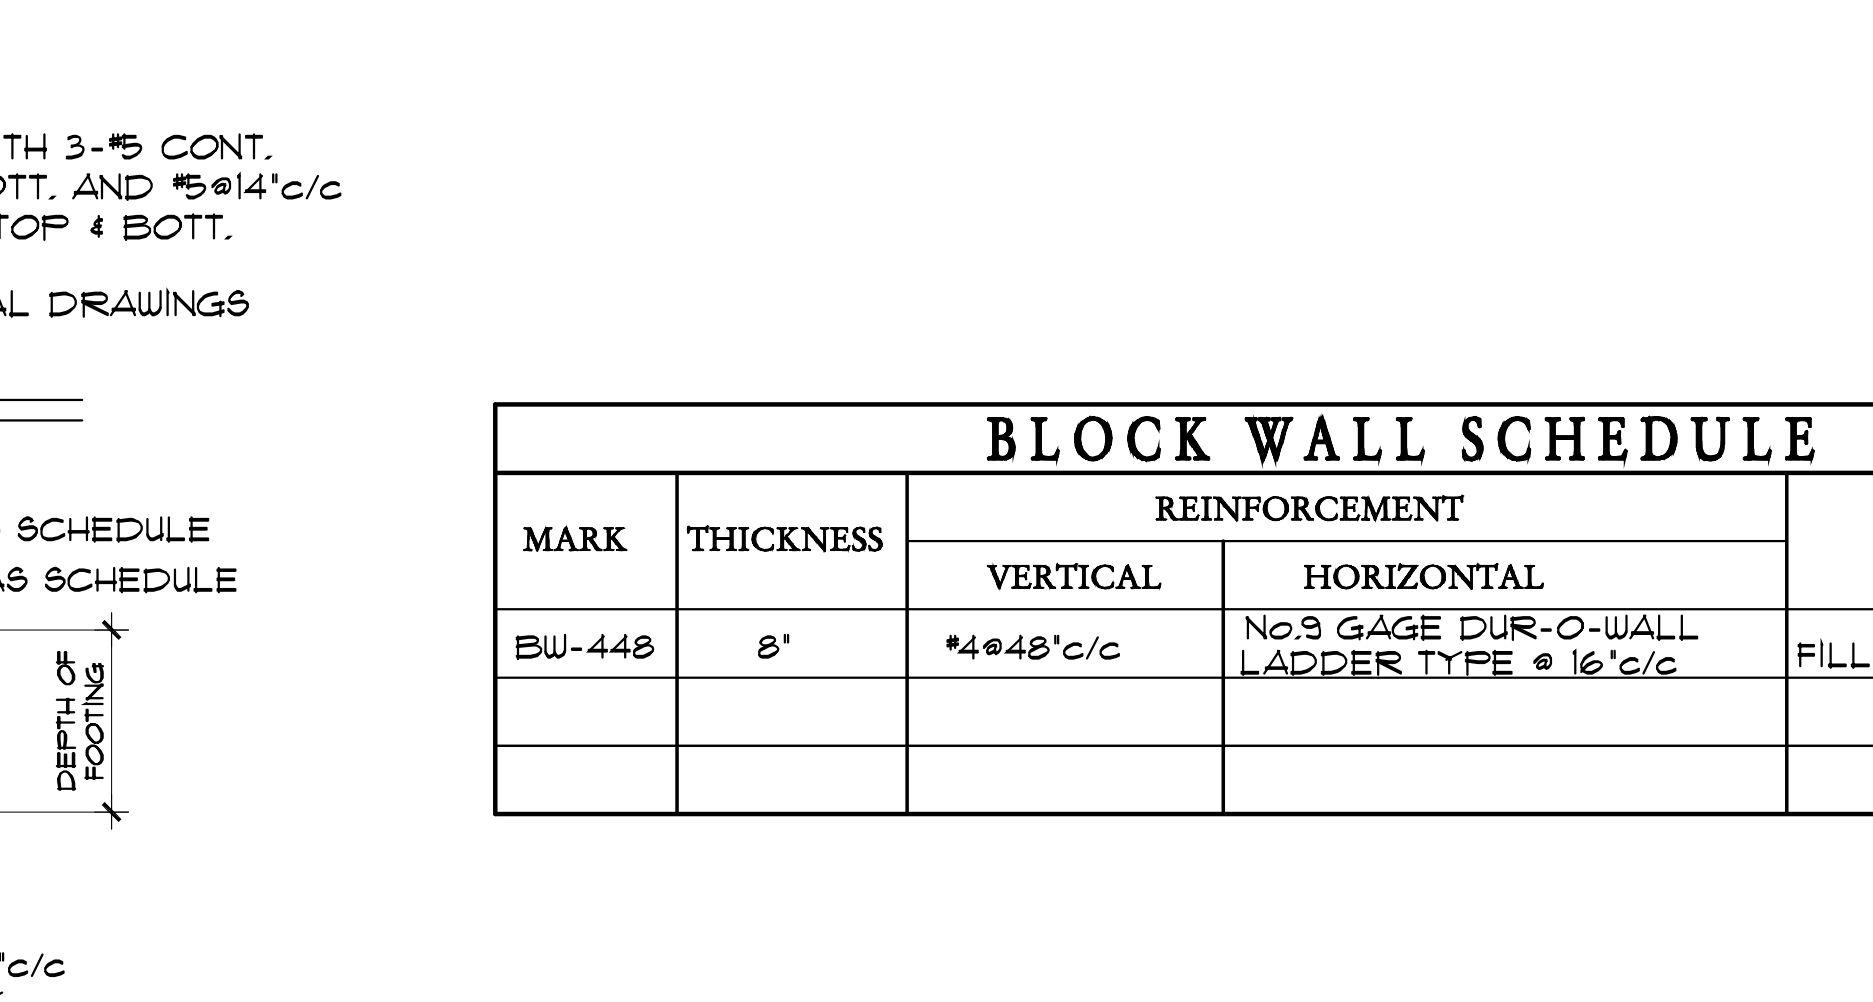


M DETAIL
 8-301 NO SCALE

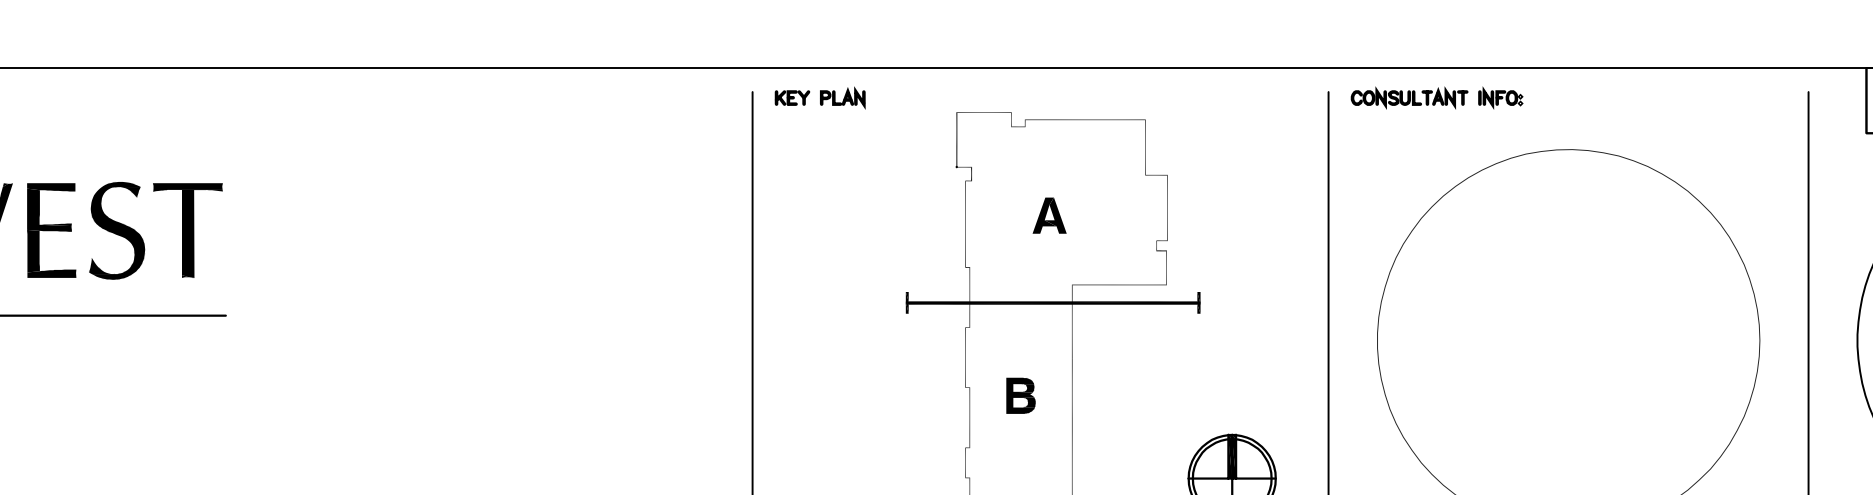


N DETAIL
 8-301 NO SCALE

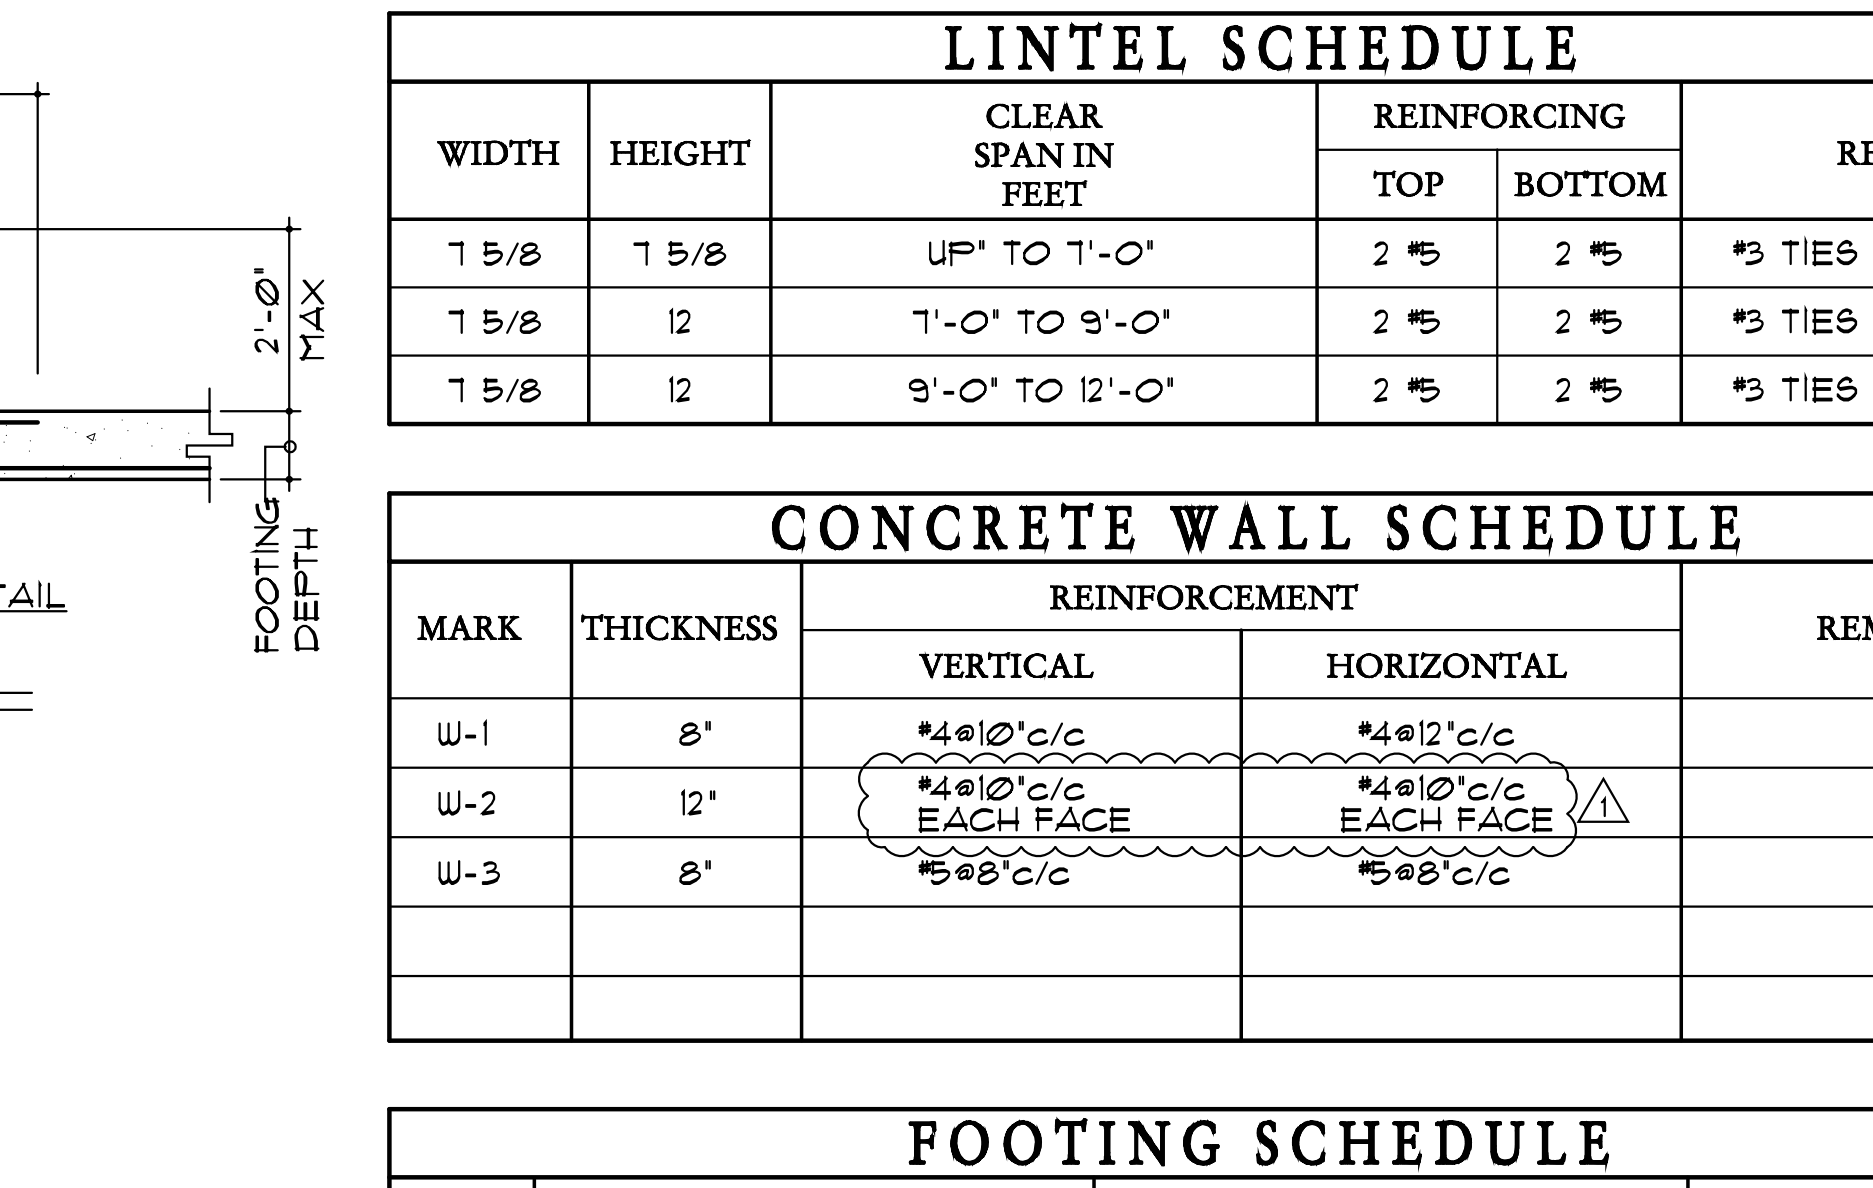


O DETAIL
 8-301 NO SCALE

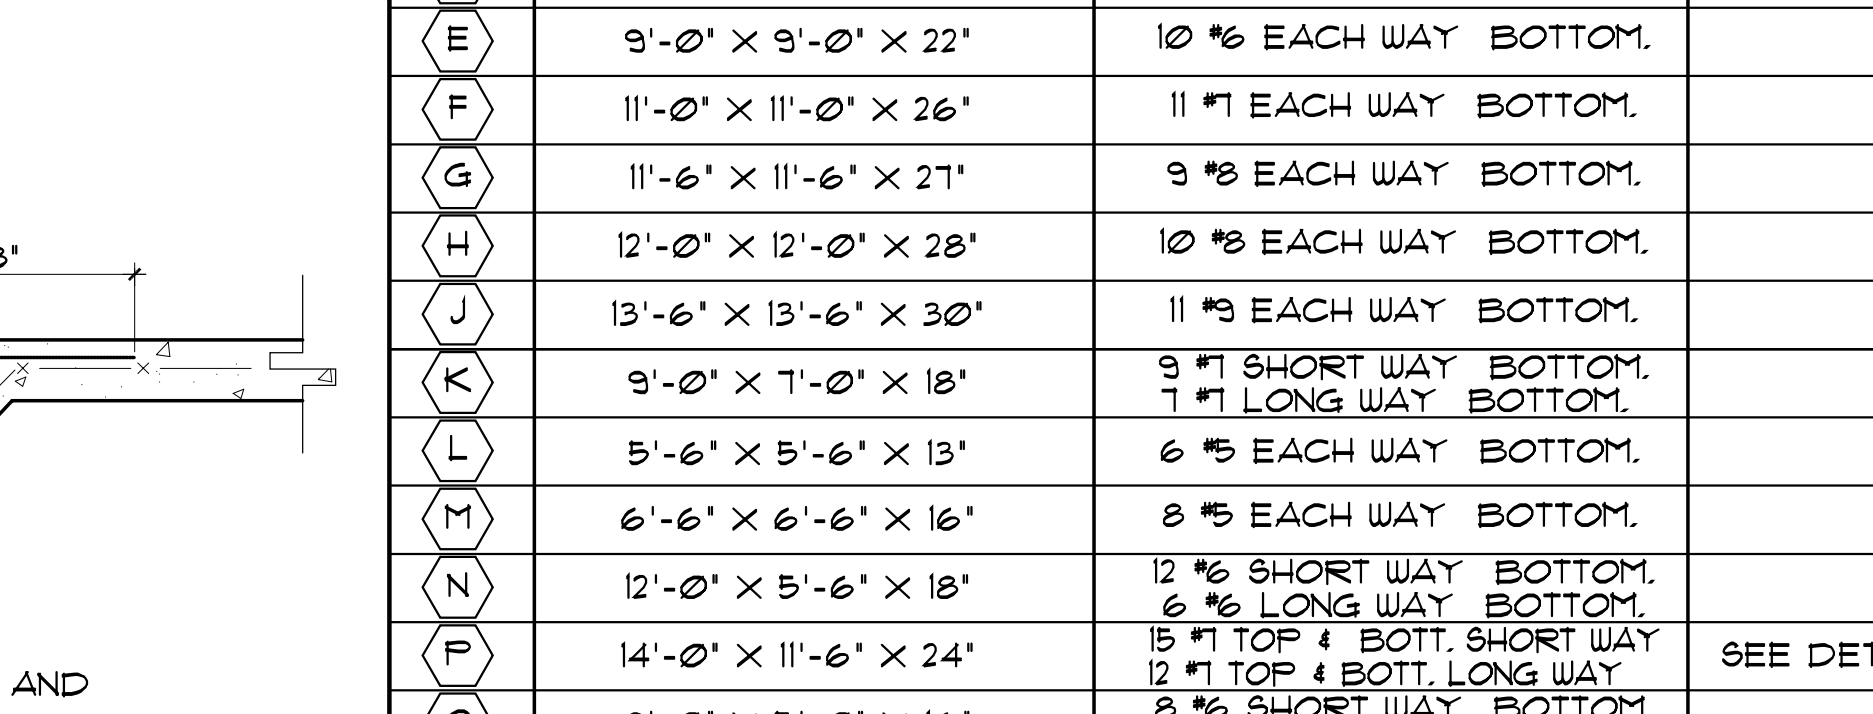


R DETAIL
 8-301 NO SCALE

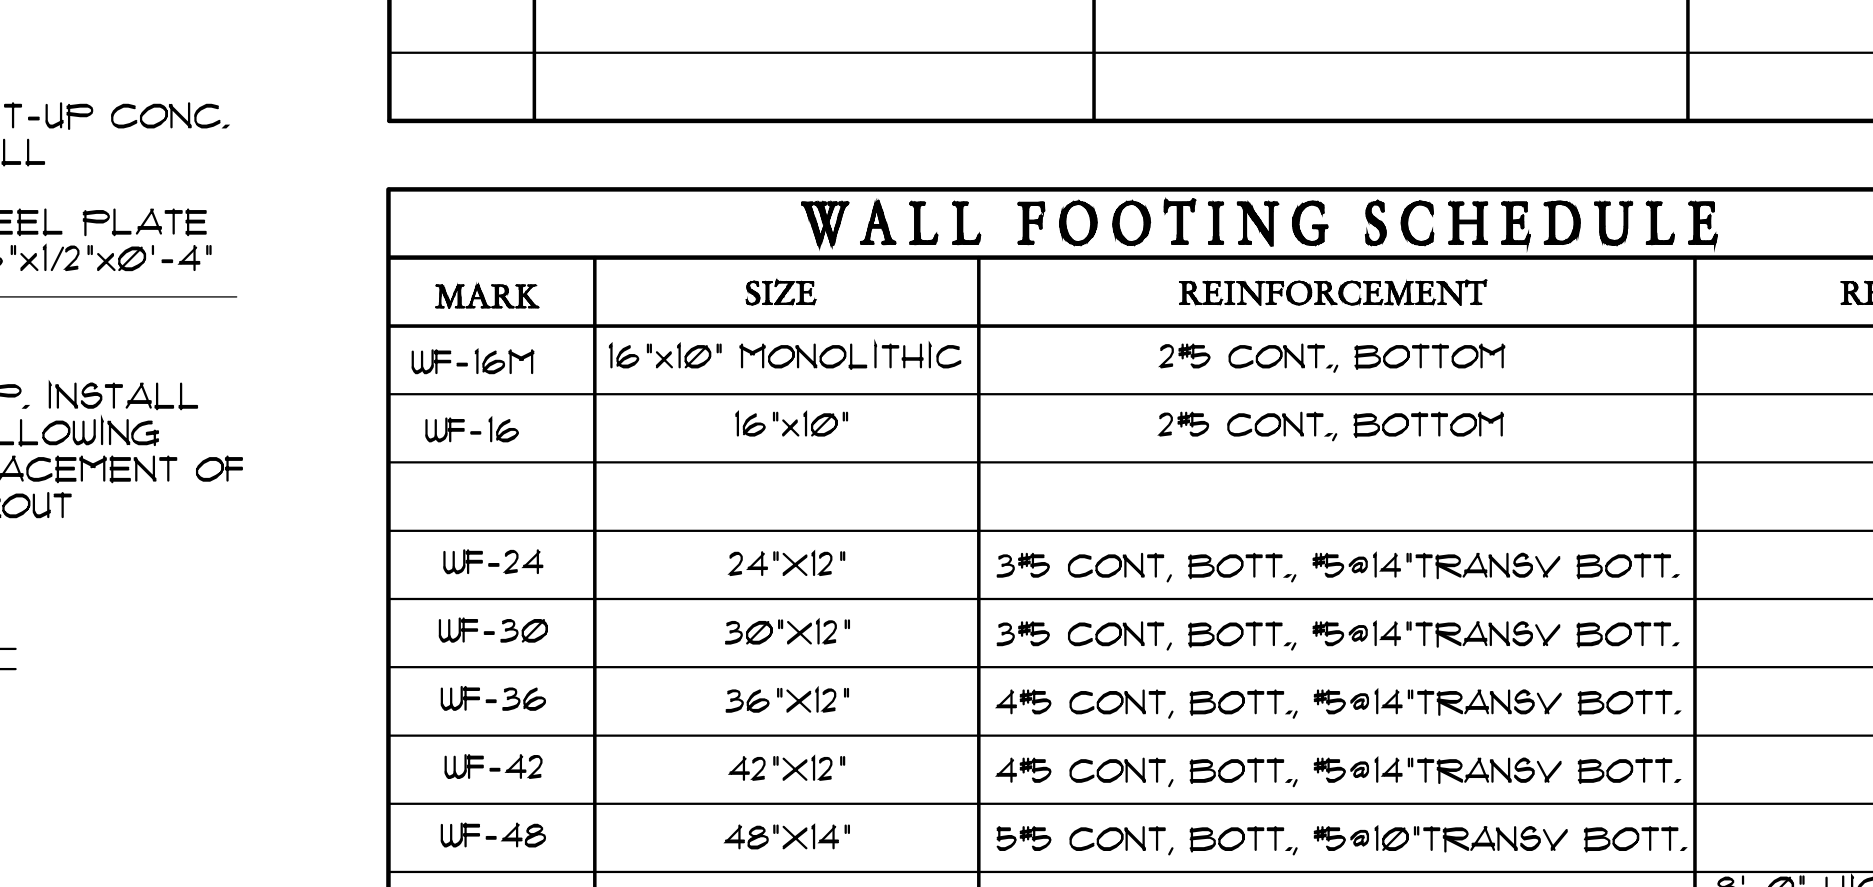

S DETAIL
 8-301 NO SCALE

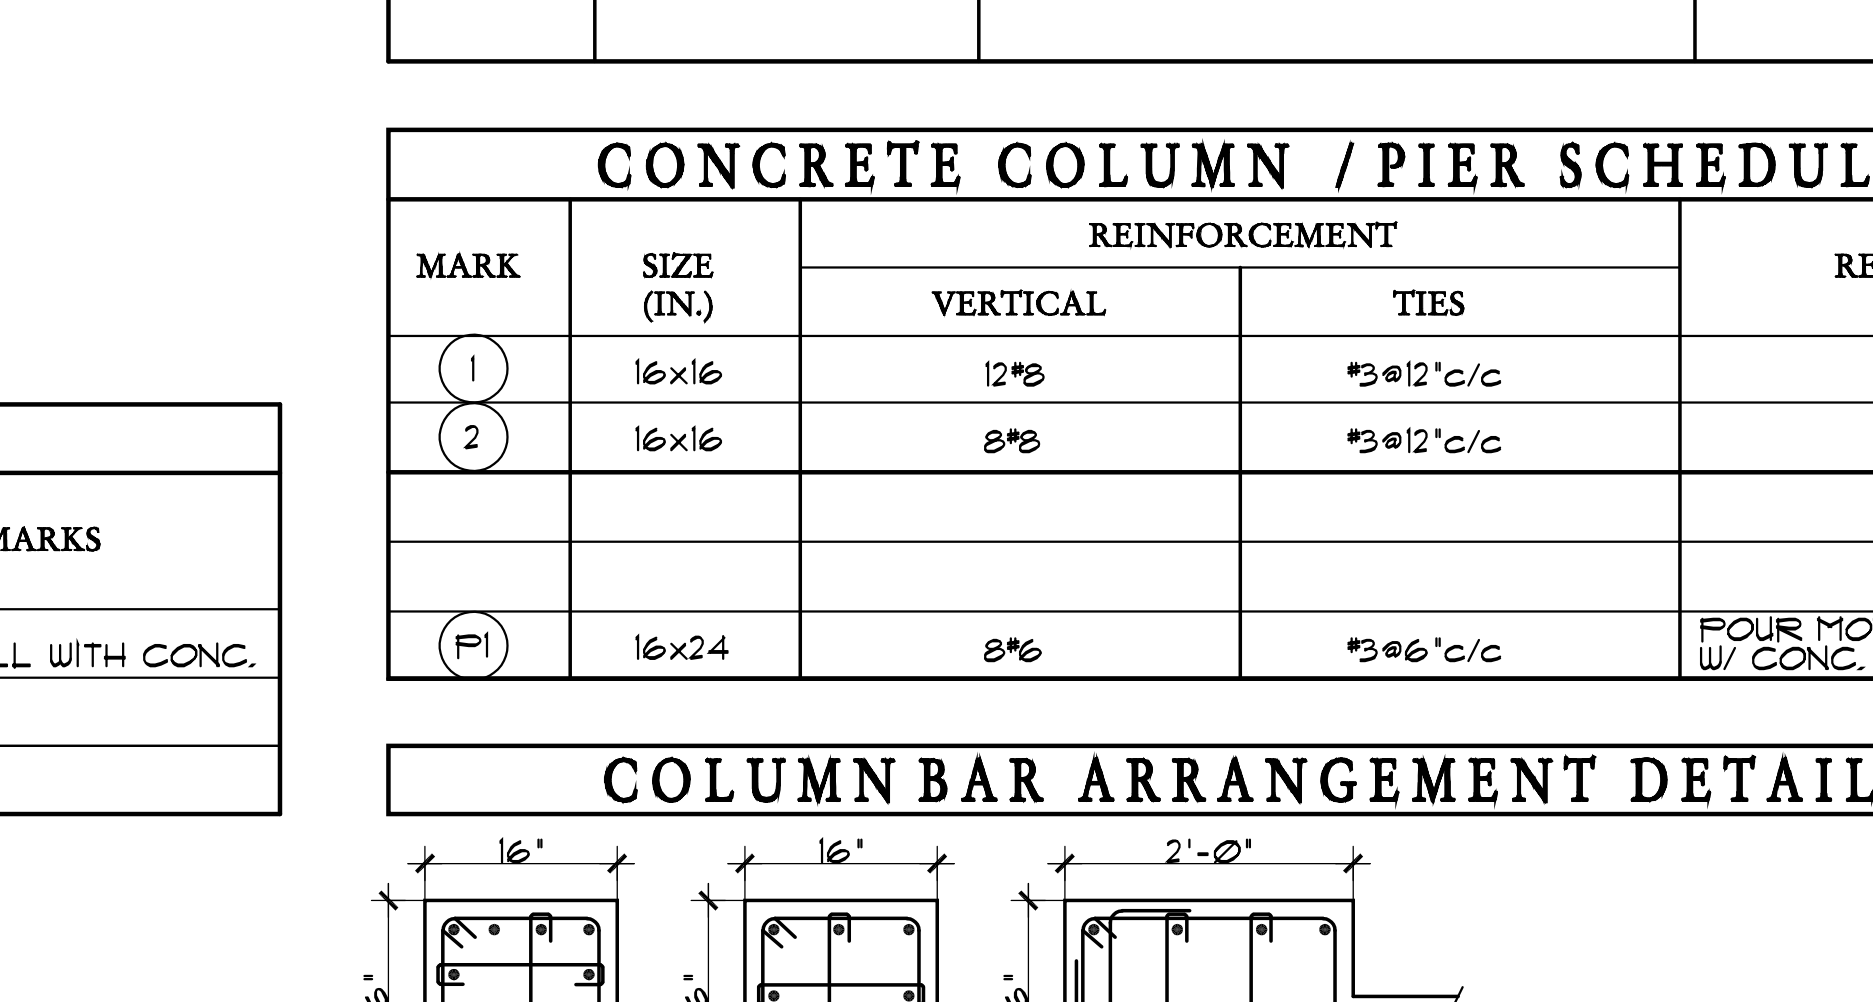

T DETAIL
 8-301 NO SCALE

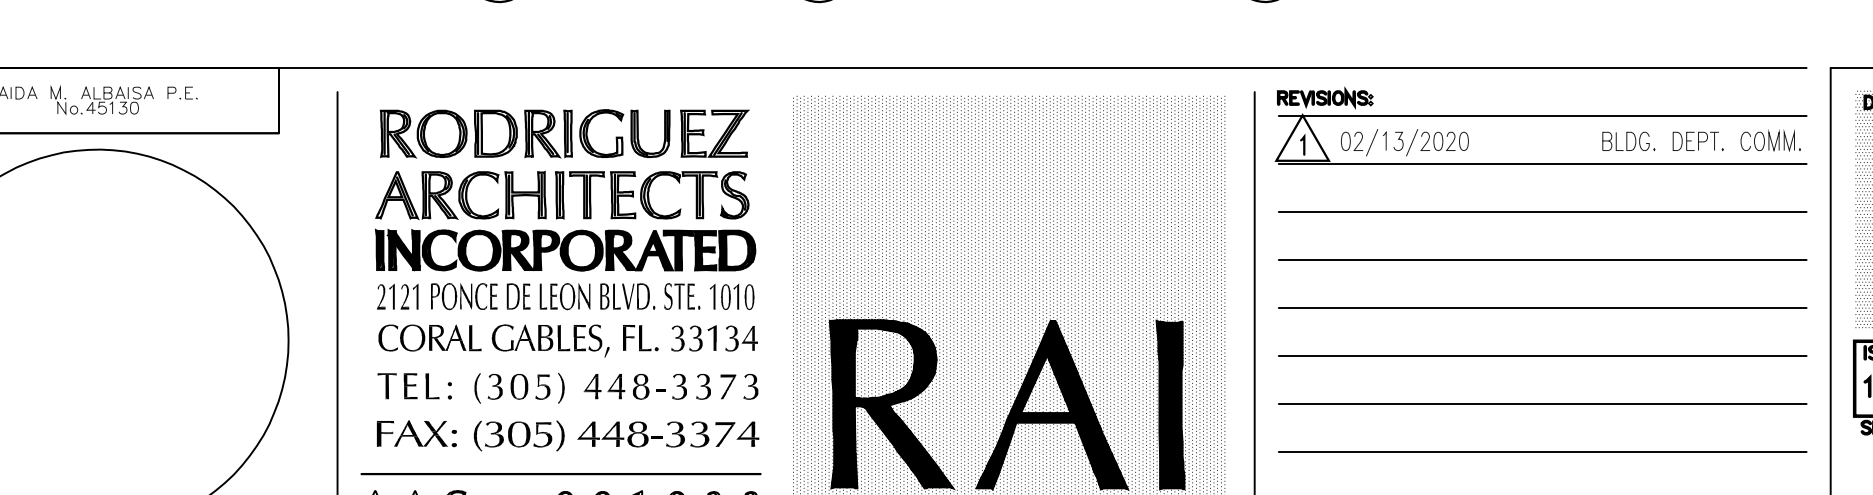

U DETAIL
 8-301 NO SCALE

LINTEL SCHEDULE					
WIDTH	HEIGHT	CLEAR SPAN IN FEET	REINFORCING		REMARKS
			TOP	BOTTOM	
7 5/8	7 5/8	UP TO 7'-0"	2 #5	2 #5	#3 TIES @ 12" c/c
7 5/8	12	7'-0" TO 9'-0"	2 #5	2 #5	#3 TIES @ 12" c/c
7 5/8	12	9'-0" TO 12'-0"	2 #5	2 #5	#3 TIES @ 12" c/c

CONCRETE WALL SCHEDULE					
MARK	THICKNESS	REINFORCEMENT		REMARKS	
		VERTICAL	HORIZONTAL		
W-1	8"	#4 @ 10" c/c	#4 @ 12" c/c		
W-2	12"	#4 @ 10" c/c	#4 @ 10" c/c		
W-3	8"	#5 @ 8" c/c	#5 @ 8" c/c		


FOOTING SCHEDULE			
MARK	SIZE	REINFORCEMENT	REMARKS
A	4'-6" x 4'-6" x 12"	4 #5 EACH WAY BOTTOM	
B	5'-0" x 5'-0" x 12"	5 #5 EACH WAY BOTTOM	
C	7'-6" x 7'-6" x 18"	7 #6 EACH WAY BOTTOM	
D	8'-6" x 8'-6" x 20"	9 #6 EACH WAY BOTTOM	
E	9'-0" x 9'-0" x 22"	10 #6 EACH WAY BOTTOM	
F	11'-0" x 11'-0" x 26"	11 #7 EACH WAY BOTTOM	
G	11'-6" x 11'-6" x 27"	9 #8 EACH WAY BOTTOM	
H	12'-0" x 12'-0" x 28"	10 #8 EACH WAY BOTTOM	
J	13'-6" x 13'-6" x 30"	11 #8 EACH WAY BOTTOM	
K	9'-0" x 7'-0" x 18"	9 #7 SHORT WAY BOTTOM, 7 #7 LONG WAY BOTTOM	
L	5'-6" x 5'-6" x 13"	6 #5 EACH WAY BOTTOM	
M	6'-6" x 6'-6" x 16"	8 #5 EACH WAY BOTTOM	
N	12'-0" x 5'-6" x 18"	12 #6 SHORT WAY BOTTOM, 6 #6 LONG WAY BOTTOM	
P	14'-0" x 11'-6" x 24"	15 #7 TOP & BOTT, SHORT WAY 12 #7 TOP & BOTT, LONG WAY	SEE DETAIL R/8-301
Q	8'-0" x 5'-0" x 16"	8 #6 SHORT WAY BOTTOM, 5 #6 LONG WAY BOTTOM	
R	10'-0" x 4'-0" x 16"	10 #6 SHORT WAY BOTTOM, 4 #6 LONG WAY BOTTOM	
S	9'-0" x 6'-0" x 18"	9 #6 SHORT WAY BOTTOM, 6 #6 LONG WAY BOTTOM	

WALL FOOTING SCHEDULE			
MARK	SIZE	REINFORCEMENT	REMARKS
WF-16M	16'x10' MONOLITHIC	2#5 CONT, BOTTOM	
WF-16	16'x10'	2#5 CONT, BOTTOM	
WF-24	24'x12'	3#5 CONT, BOTT, #5@14" TRANSV BOTT	
WF-30	30'x12'	3#5 CONT, BOTT, #5@14" TRANSV BOTT	
WF-36	36'x12'	4#5 CONT, BOTT, #5@14" TRANSV BOTT	
WF-42	42'x12'	4#5 CONT, BOTT, #5@14" TRANSV BOTT	
WF-48	48'x14'	5#5 CONT, BOTT, #5@10" TRANSV BOTT	
WF-48A	48'x14'	5#5 CONT, BOTT, #5@10" TRANSV BOTT	8'-0" HIGH WALL SECTION 2/3-406
WF-60	60'x14'	6#5 CONT, BOTT, #5@10" TRANSV BOTT	
WF-60A	60'x14'	6#5 CONT TOP & BOTT, #5@10" c/c TRANSV TOP & BOTT	
WF-84	84'x18'	7#6 CONT TOP & BOTT, #6@12" c/c TRANSV TOP & BOTT	

CONCRETE COLUMN / PIER SCHEDULE				
MARK	SIZE (IN.)	REINFORCEMENT		REMARKS
		VERTICAL	TIES	
(1)	16x16	12#8	#3@12" c/c	
(2)	16x16	8#8	#3@12" c/c	
(P1)	16x24	8#6	#3@6" c/c	FOUR MONOLITHIC W/ CONC. WALL

COLUMN BAR ARRANGEMENT DETAILS			
12 BARS	8 BARS	8 BARS	PIER (P)

BLOCK WALL SCHEDULE				
MARK	THICKNESS	REINFORCEMENT		REMARKS
		VERTICAL	HORIZONTAL	
BW-448	8"	#4 @ 48" c/c	No. 9 GAGE DUR-O-WALL LADDER TYPE @ 16" c/c	FILL CELL WITH CONC.

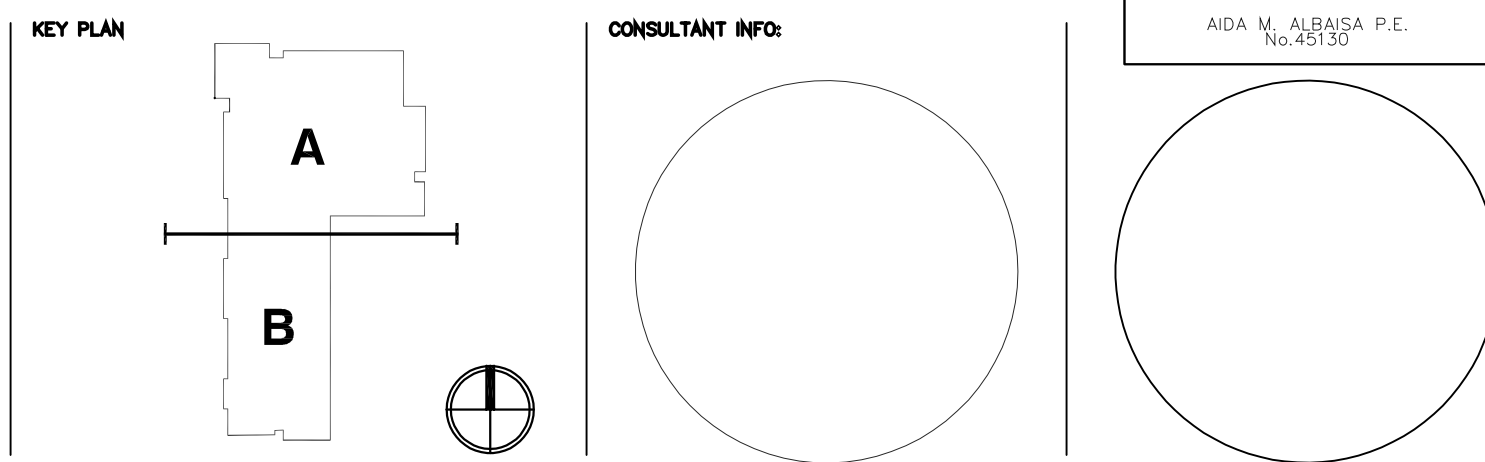

D.D.A. ENGINEERS, P.A. CONSULTING
 4930 S.W. 74TH COURT
 MIAMI, FLORIDA 33155
 Phone: (305) 666-0711
 Fax: (305) 666-6269
 www.ddaeng.com
 2019-42-A

MIAMI-DADE COUNTY
 giving our students the world
 PUBLIC SCHOOLS

NEW ELEMENTARY SCHOOL (K-5)
VENETIAN PARC WEST
 SOUTHWEST 157th AVENUE and 174th STREET
 MIAMI, FL 33187
 MDCPS PROJECT No. 01892600

KEY PLAN

CONSULTANT INFO

ADA M. ALBARRA P.E.
 10/11/19

RODRIGUEZ ARCHITECTS INCORPORATED
 3121 PONCE DE LEON BLVD. STE 100
 CORAL GABLES, FL 33134
 TEL: (305) 448-3373
 FAX: (305) 448-3374
 AAC -- 001933


REVISIONS

02/13/2020 BLDG. DEPT. COMM.

DRAWING TITLE


SCHEDULES AND DETAILS
 SCALE: AS NOTED
 ISSUE DATE: 10.11.19
 PROJECT NO: 1906
S-301



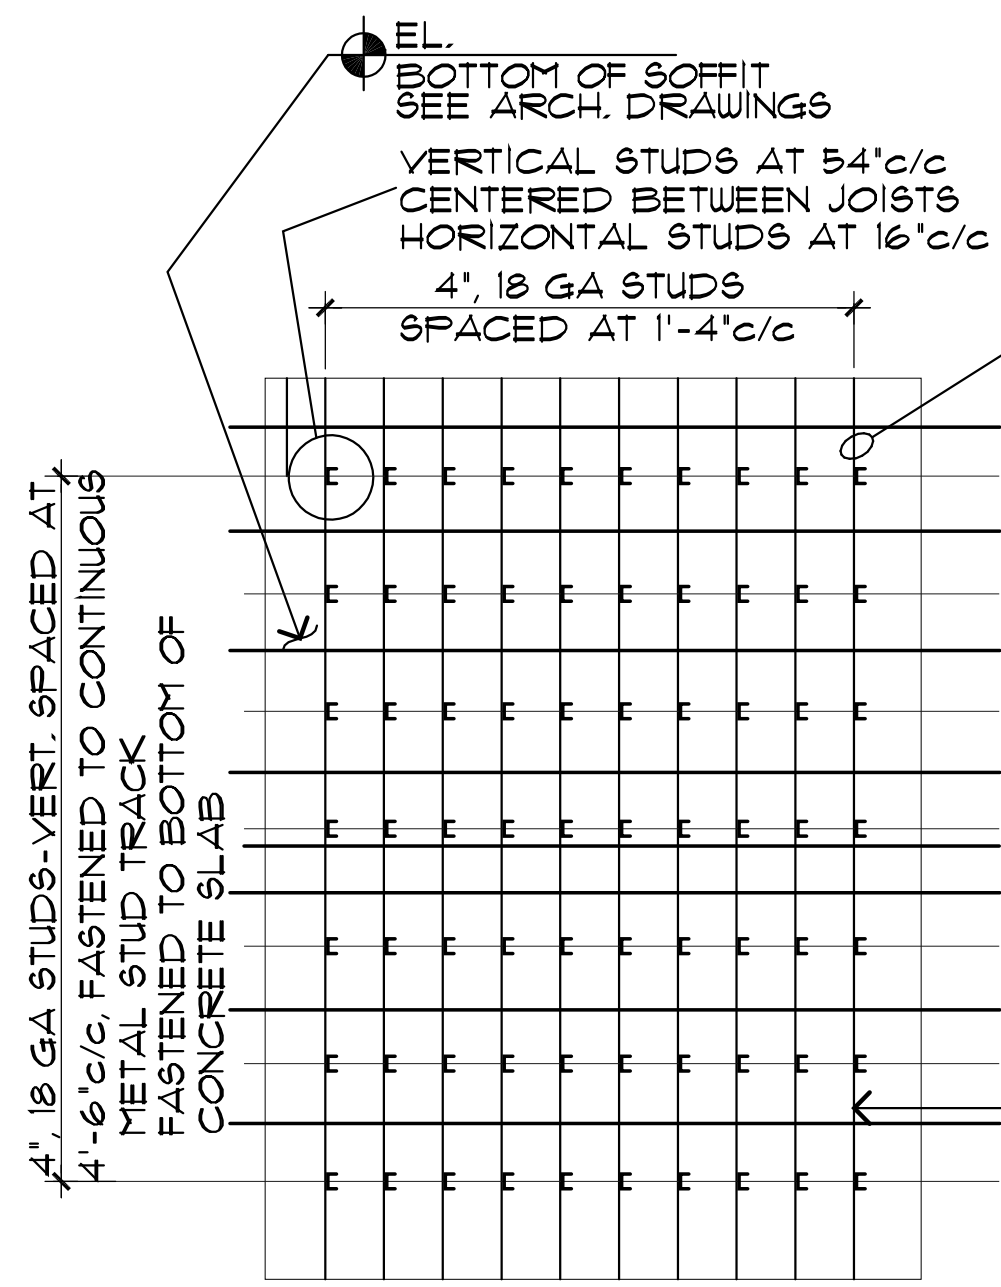

EXTERIOR CEILING SOFFIT DETAIL FOR CONC. JOIST/SLAB FRAMING

SCALE: N.T.S.

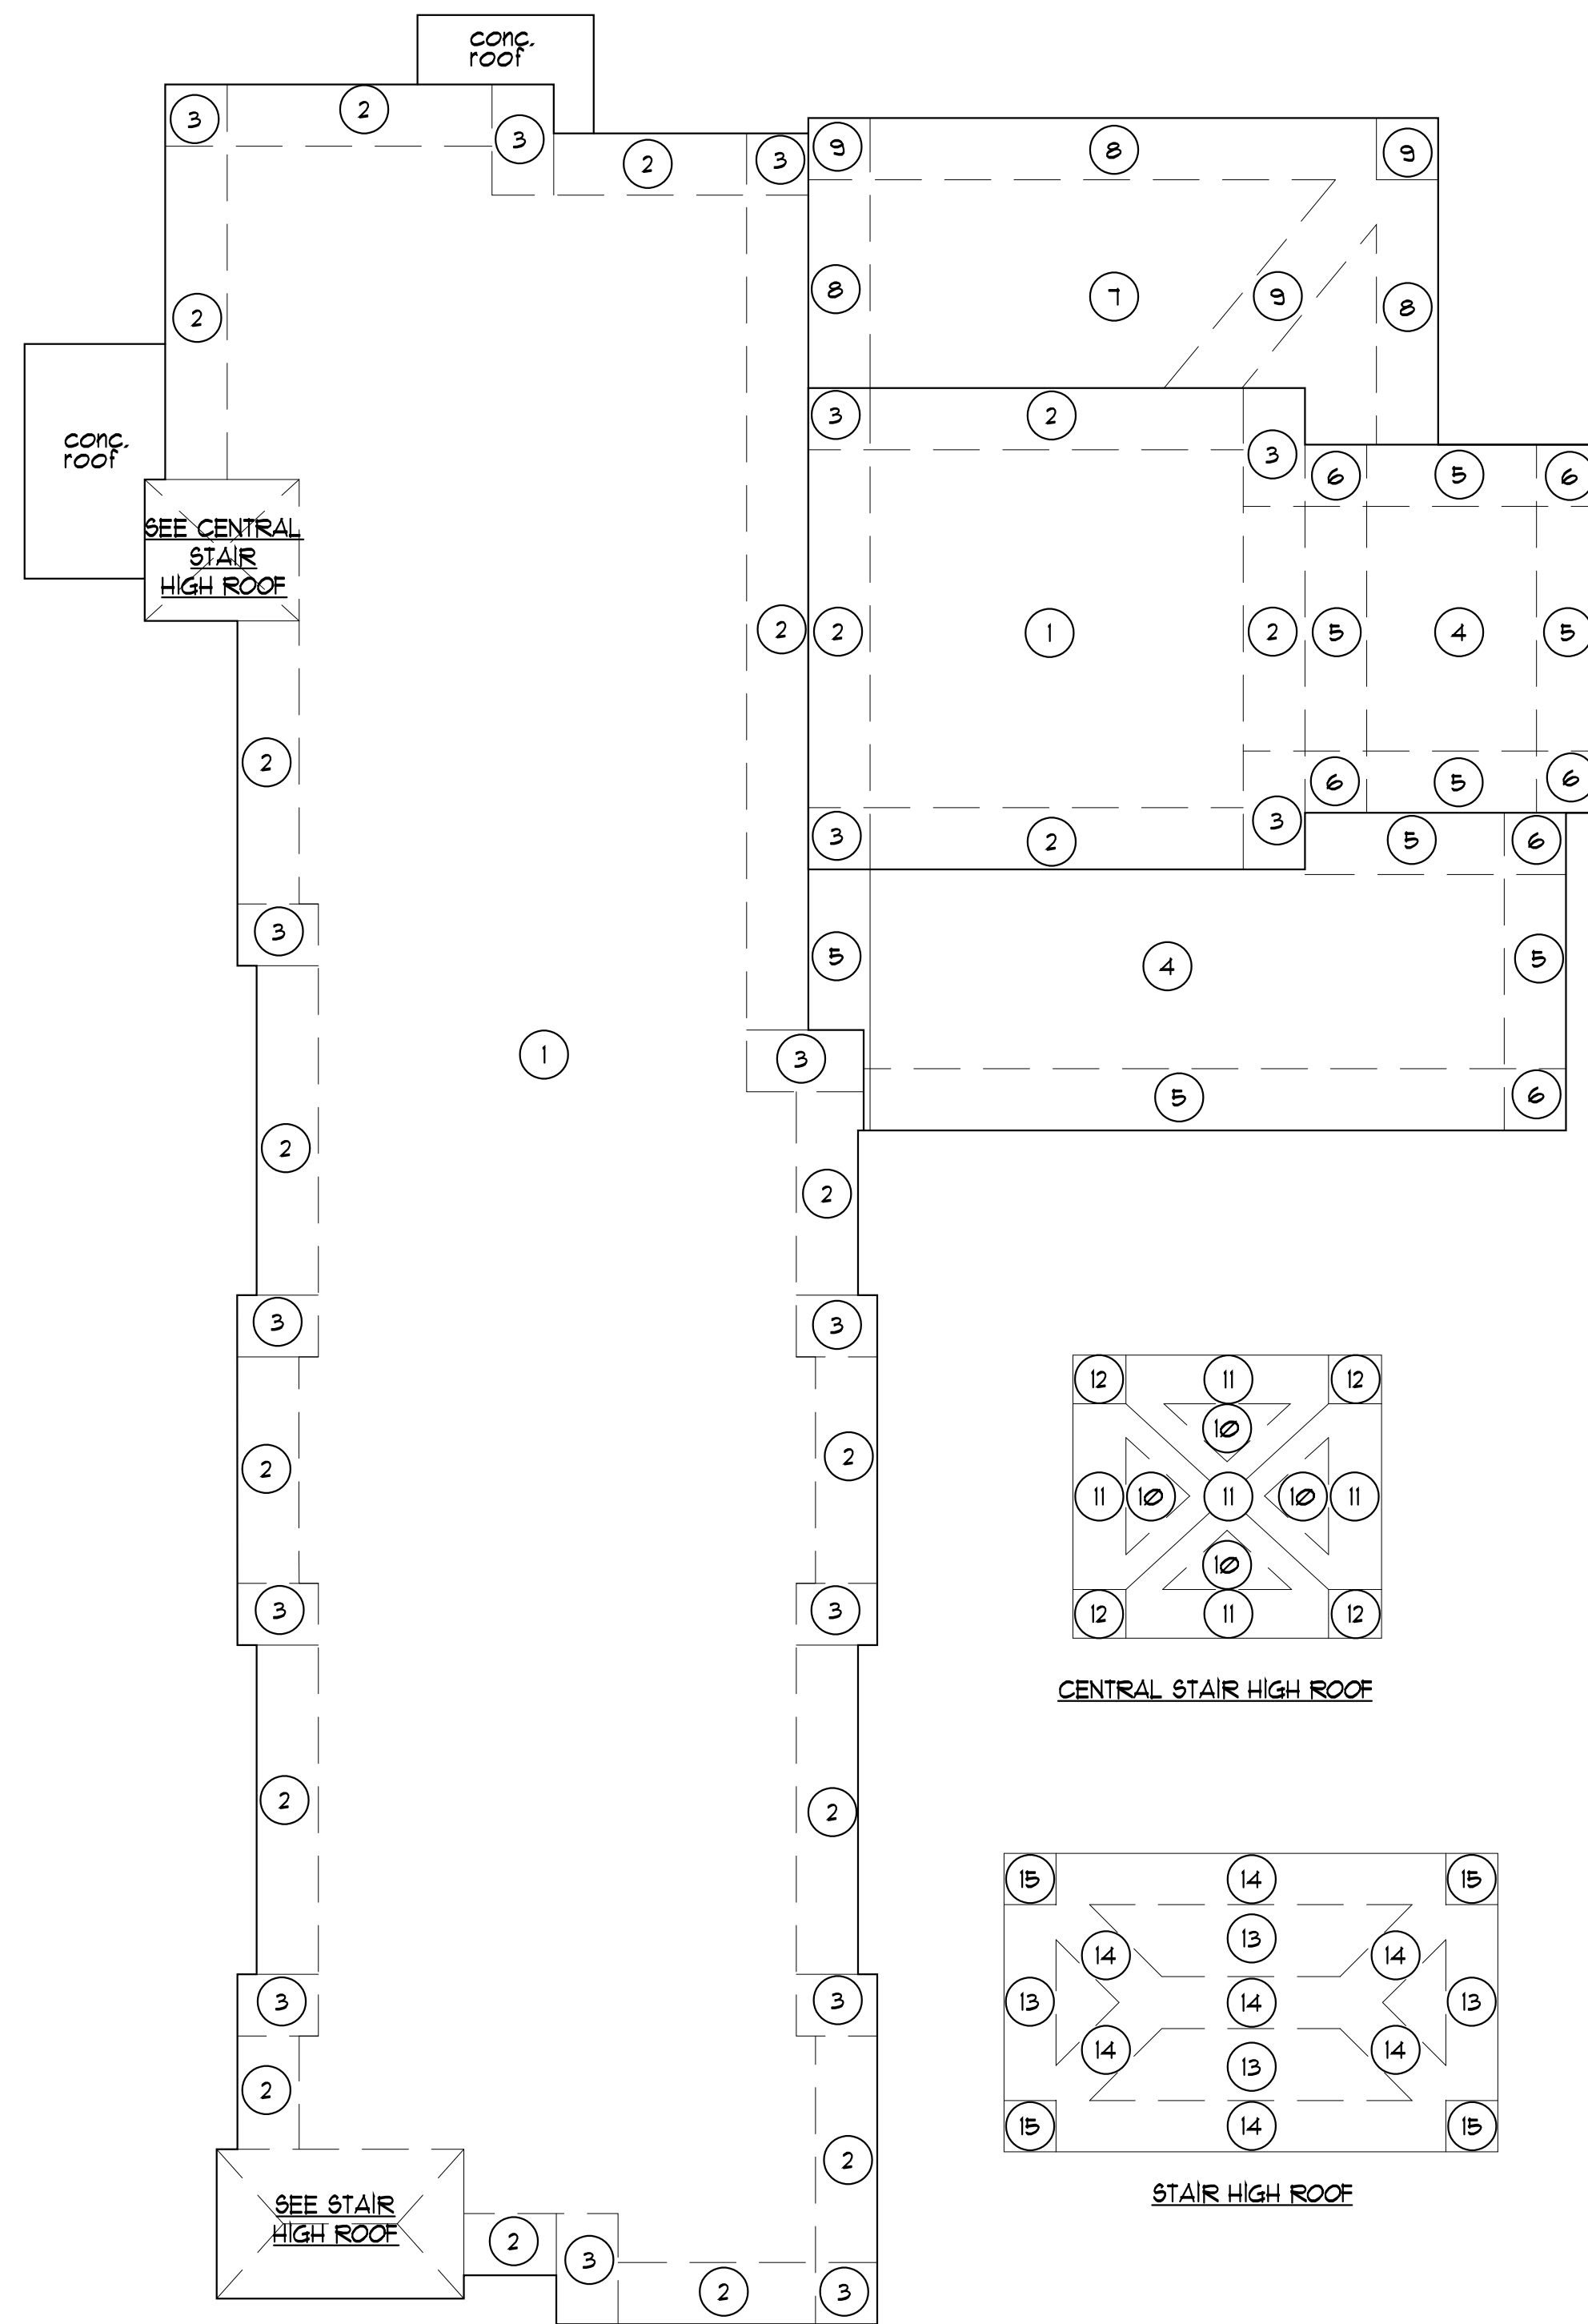

UPLIFT DIAGRAM


SCALE: N.T.S.

STRUCTURAL METAL STUD NOTES:

AS PER ASCE 7-2010

- ALL METAL STUDS SHALL BE 4" STANDARD, 18" FLANGE WIDTH, 18 GAGE, SPACED AT 16" (IN) CENTER TO CENTER.
- ALL METAL STUD TRACKS SHALL BE 4" STD, 18 GAGE, TYPICAL UNLESS OTHERWISE NOTED.
- ALL STUD TO STUD CONNECTIONS SHALL BE MADE WITH TWO (2) NO. 10-16 SCREWS, 0.193 DIAMETER, TYPICAL UNLESS OTHERWISE NOTED.
- ALL METAL TRACK CONNECTIONS TO CONCRETE TO BE MADE WITH TWO (2) 0.111 (IN) SHANK DIAMETER POWER DRIVEN FASTENERS AT 16" CENTER TO CENTER, TYPICAL UNLESS OTHERWISE NOTED.

REFER TO STRUCTURAL METAL STUD NOTES BELOW FOR CONNECTIONS TO WALLS

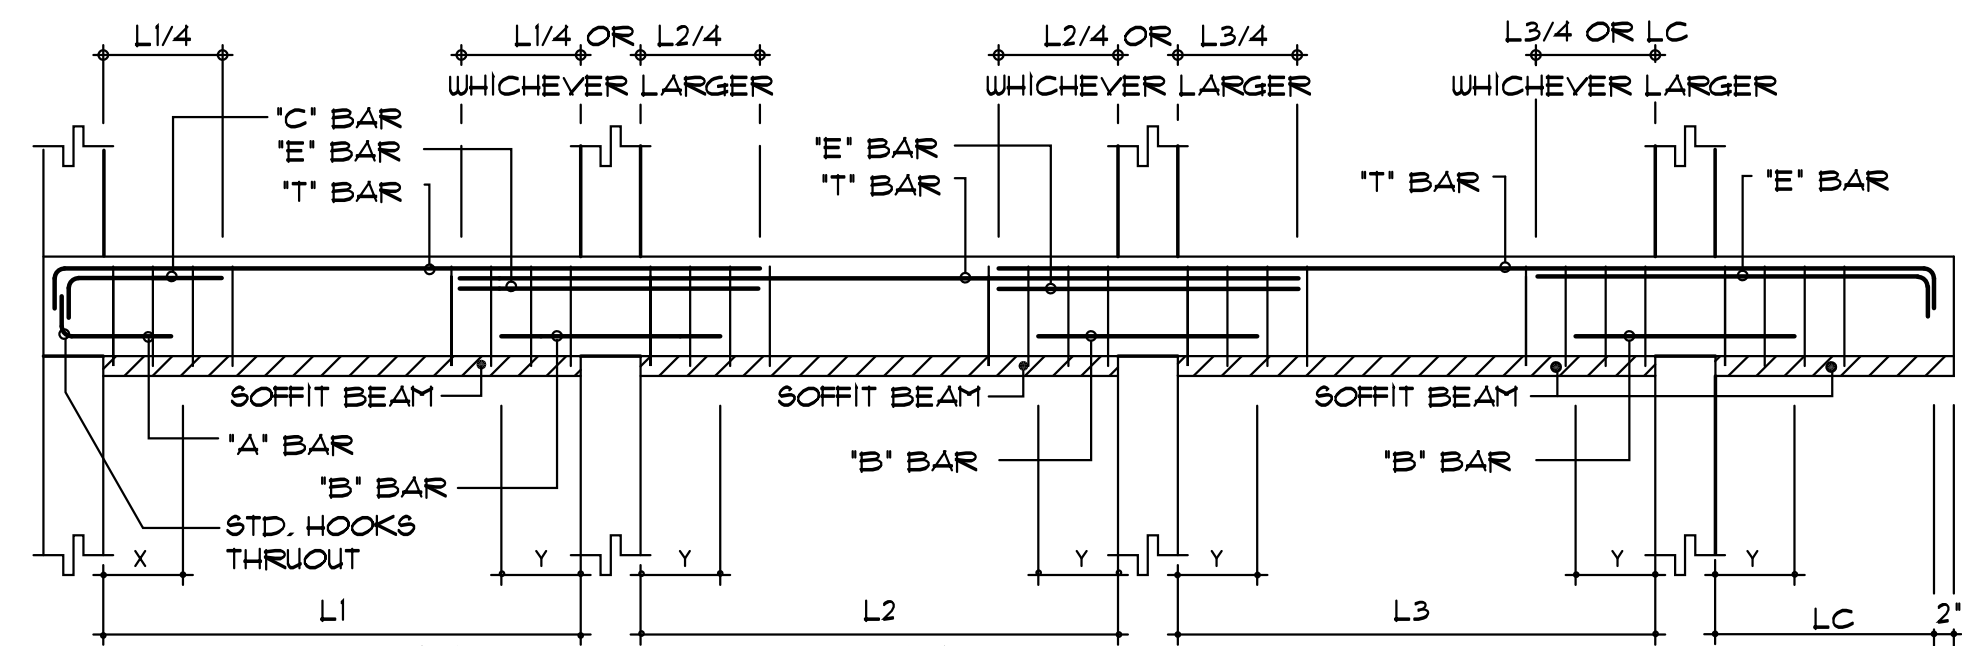

TYPICAL SOFFIT BEAM DIAGRAM

NOTES:


- A' - SHEAR FRICTION BAR - OVER COL. AT DISCONTINUOUS ENDS.
- B' - SHEAR FRICTION BAR - OVER COL. AT INTERIOR RIGHT SUPPORT.
- C' - TOP BARS AT DISCONTINUOUS ENDS.
- E' - TOP BARS AT INTERIOR RIGHT SUPPORT.
- T' - TOP BARS EXTENDED INTO ADJACENT SPANS, U.O.N. (SEE DIAG.)
- MU' - DESIGN POSITIVE MOMENT AT MIDSPAN (FT. KIPS), (ULTIMATE)
- VS' - DESIGN SHEAR AT DISTANCE 'd' FROM FACE OF SUPPORT (KIPS), (ULTIMATE)
- TU' - DESIGN TORSIONAL MOMENT AT DISTANCE 'd' FROM FACE OF SUPPORT (FT. KIPS).
- X' - EMBEDMENT LENGTH OF SHEAR FRICTION BAR (INCHES)
- U' - BEAM WIDTH (IN).
- D' - BEAM TOTAL DEPTH (IN).

PROVIDE 5#12' c/c HORIZONTAL INTERMEDIATE SKIN REINFORCING FOR ALL SOFFIT BEAMS DEEPER THAN 24"

SHEAR FRICTION FOR SOFFITS

BAR SIZE	1/2"	3/4"	1"	1 1/4"	1 1/2"
EMBEDMENT LENGTH "X"	4'-0"	5'-0"	5'-6"	7'-8"	8'-8"

TYPICAL SECTION

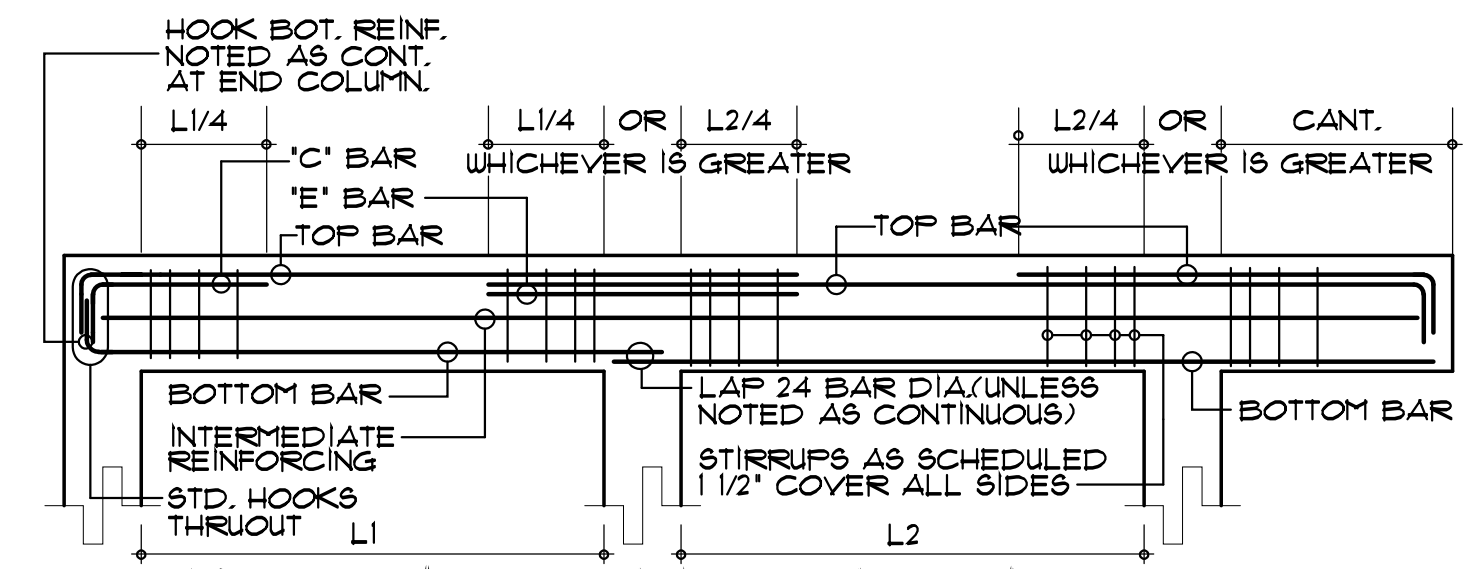

TYPICAL BEAM DIAGRAM

NOTES:

- 1. 'C' BARS ARE TOP BARS AT NON-CONTINUOUS ENDS.
- 2. 'E' BARS ARE TOP BARS OVER RIGHT INTERIOR SUPPORTS.
- 3. TOP BARS CALLED FOR AS CONTINUOUS WHEN SPLICED, SHALL BE SPLICED IN THE MIDDLE THIRD OF THE SPAN.
- 4. REFER TO INTERMEDIATE BEAM REINFORCING FOR ADDITIONAL REINFORCING.
- 5. PROVIDE AT ALL NON-BEARING BLOCK WALLS, A TIE-BEAM 3"x12" (MIN) WITH 2#5 TOP AND BOTTOM CONT. #3 TIES, 4 AT 12" c/c EACH END, BAL. AT 48" c/c. TIE-BEAMS MUST BE DOVELED INTO WALLS AT EACH END, AT INTERSECTIONS, AT INTERMEDIATE POINTS.
- 6. TIE-BEAM DEPTH, AS SCHEDULED, IS MINIMUM CAN BE INCREASED AS REQUIRED TO MATCH BLOCK COURSE. PROVIDE 1#5 E/F/ADD'L IF INCREASE IN DEPTH EXCEEDS 8".

WINDLOAD PRESSURE FOR WINDOWS, DOORS AND PANELS. (POUNDS PER SQUARE FOOT) (A.S.D.)

AREA	ZONE (4)		ZONE (5)	
	POSITIVE	NEGATIVE	POSITIVE	NEGATIVE
10 ft. to 25 ft.	48 P.S.F.	52 P.S.F.	48 P.S.F.	64 P.S.F.
26 ft. to 50 ft.	45 P.S.F.	49 P.S.F.	45 P.S.F.	58 P.S.F.
51 ft. to 100 ft.	43 P.S.F.	47 P.S.F.	43 P.S.F.	54 P.S.F.
101 ft. to 250 ft.	41 P.S.F.	46 P.S.F.	41 P.S.F.	50 P.S.F.
251 ft. to 500 ft.	38 P.S.F.	42 P.S.F.	38 P.S.F.	45 P.S.F.
501 ft. AND UP	36 P.S.F.	40 P.S.F.	36 P.S.F.	40 P.S.F.

- NOTES:
- ZONE (4) IS DEFINED AS ANY DOOR OR WINDOW WITHIN 8'-6" FROM ANY CORNER OF THE BUILDING. ALL OTHER LOCATIONS ARE DEFINED AS ZONE (5).
 - VALUES INDICATED CAN BE INTERPOLATED.
 - Kd VALUE 0.25

NOTE: THE WIND PRESSURES INDICATED ON THE TABLES ARE TO BE USED WITH LOAD COMBINATIONS OF ASCE-7-10

WIND LOAD PRESSURES FOR ROOFING DESIGN (A.S.D.)

ZONE	PRESSURE (POUNDS PER SQUARE FOOT)
1	45 P.S.F.
2	80 P.S.F.
3	124 P.S.F.
4	39 P.S.F.
5	70 P.S.F.
6	108 P.S.F.
7	51 P.S.F.
8	63 P.S.F.
9	114 P.S.F.
10	43 P.S.F.
11	81 P.S.F.
12	124 P.S.F.
13	43 P.S.F.
14	79 P.S.F.
15	120 P.S.F.

NET WIND UPLIFT LOADS FOR TRUSS DESIGN (A.S.D.)

ZONE	PRESSURE (POUNDS PER SQUARE FOOT)
1	45 P.S.F.
8	50 P.S.F.
9	80 P.S.F.
10	41 P.S.F.
11	60 P.S.F.
12	38 P.S.F.
13	39 P.S.F.
14	51 P.S.F.
15	35 P.S.F.


SOFFIT BEAM SCHEDULE

MARK	TOP OF BEAM ELEV	SIZE W & D (IN)	REINFORCEMENT					STIRRUP CRITERIA		REMARKS	
			+MU (K&T)	"A"	"B"	"T"	"C"	"E"	LEFT VU (K)		RIGHT VU (K)
28B-1	+13'-8"	16"x28"	140	2#	3#	(+) 5#			26	58	(+) CONT.
28B-2	+13'-8"	16"x28"	360		3#	(+) 5#			79	57	(+) CONT.
28B-3	+13'-8"	16"x30"	370	2#	3#	4#			37	59	
28B-4	+13'-8"	16"x24"	30	2#	2#	(+) 3#			8	18	(+) CONT.
28B-5	+13'-8"	16"x24"	68		1#	(+) 3#			21	13	(+) CONT.
28B-6	+13'-8"	24"x24"	110	2#	4#	(+) 5#	1#		30	62	(+) CONT.
28B-7	+13'-8"	24"x24"	280		4#	(+) 5#	2#		92	96	(+) CONT.
28B-8	+13'-8"	24"x24"	232		4#	(+) 5#	(+) 2#		90	85	(+) CONT. HOOK BARS @ COL. @ RIGHT END. (++) AT 2nd LAYER.
28B-9	+13'-8"	24"x22"	230		4#	(+) 5#	(+) 2#		86	91	(+) CONT.
28B-10	+13'-8"	24"x24"	282		4#	(+) 5#	2#		94	94	(+) CONT. HOOK BARS @ COL. @ LEFT END.
28B-11	+13'-8"	24"x24"	246		4#	(+) 5#	2#		92	97	(+) CONT.
28B-12	+13'-8"	24"x24"	360		3#	(+) 5#			106	65	(+) CONT.
28B-13	+13'-8"	24"x24"	76	2#	3#	(+) 5#			44	70	(+) CONT.
28B-14	+13'-8"	24"x24"	225		4#	(+) 5#	3#		80	95	(+) CONT.
28B-15	+13'-8"	24"x24"	290		3#	(+) 5#			102	70	(+) CONT.
28B-16	+13'-8"	24"x24"	100		3#	(+) 5#	2#		50	50	(+) CONT.
28B-17	+13'-8"	24"x28"	435		3#	(+) 5#			78	54	(+) CONT.
28B-18	+13'-8"	16"x24"	140	2#	2#	3#			20	25	
28B-19	+13'-8"	16"x24"	67	2#	2#	2#			15	15	
28B-20	+15'-4"	24"x32"	540	4#	5#	(+) 7#			90	145	(+) CONT.
28B-21	+15'-4"	24"x32"	540		4#	(+) 7#			145	90	(+) CONT.

R8B-1	+27'-4"	24"x24"	130	2#	4#	(+) 5#	1#		30	70	(+) CONT.
R8B-2	+27'-4"	24"x24"	300		4#	(+) 5#	2#		95	100	(+) CONT.
R8B-3	+27'-4"	24"x24"	180		3#	(+) 5#			77	71	(+) CONT.
R8B-4	+27'-4"	24"x24"	190		3#	(+) 5#	1#		71	74	(+) CONT.
R8B-5	+27'-4"	24"x24"	216		3#	(+) 5#	1#		77	78	(+) CONT.
R8B-6	+27'-4"	24"x24"	187		3#	(+) 5#	2#		75	80	(+) CONT.
R8B-7	+27'-4"	24"x24"	293		3#	(+) 5#			88	54	(+) CONT.
R8B-8	+27'-4"	24"x24"	55	2#	3#	(+) 5#			36	50	(+) CONT.
R8B-9	+27'-4"	24"x24"	168		3#	(+) 5#	2#		65	75	(+) CONT.
R8B-10	+27'-4"	24"x24"	250		4#	(+) 5#	2#		80	85	(+) CONT.
R8B-11	+30'-2"	24"x16"x5T	100		6#	(+) 5#	(+) 2#		85	85	(+) CONT. (++) AT 2nd LAYER (++) SEE SECTION 3/54.01
R8B-12	+30'-2"	24"x16"x5T	360		4#	(+) 5#			160	100	(+) CONT.

BEAM SCHEDULE

MARK	TOP OF BEAM ELEV.	SIZE (IN.)	REINFORCING				No.	STIRRUPS SPACING	REMARKS
			B	T	C	E			
RB-1	+30'-2"	8"x62"	2#	2#			3	#12' c/c	ADD 2# E/F, E.Q. SPACE

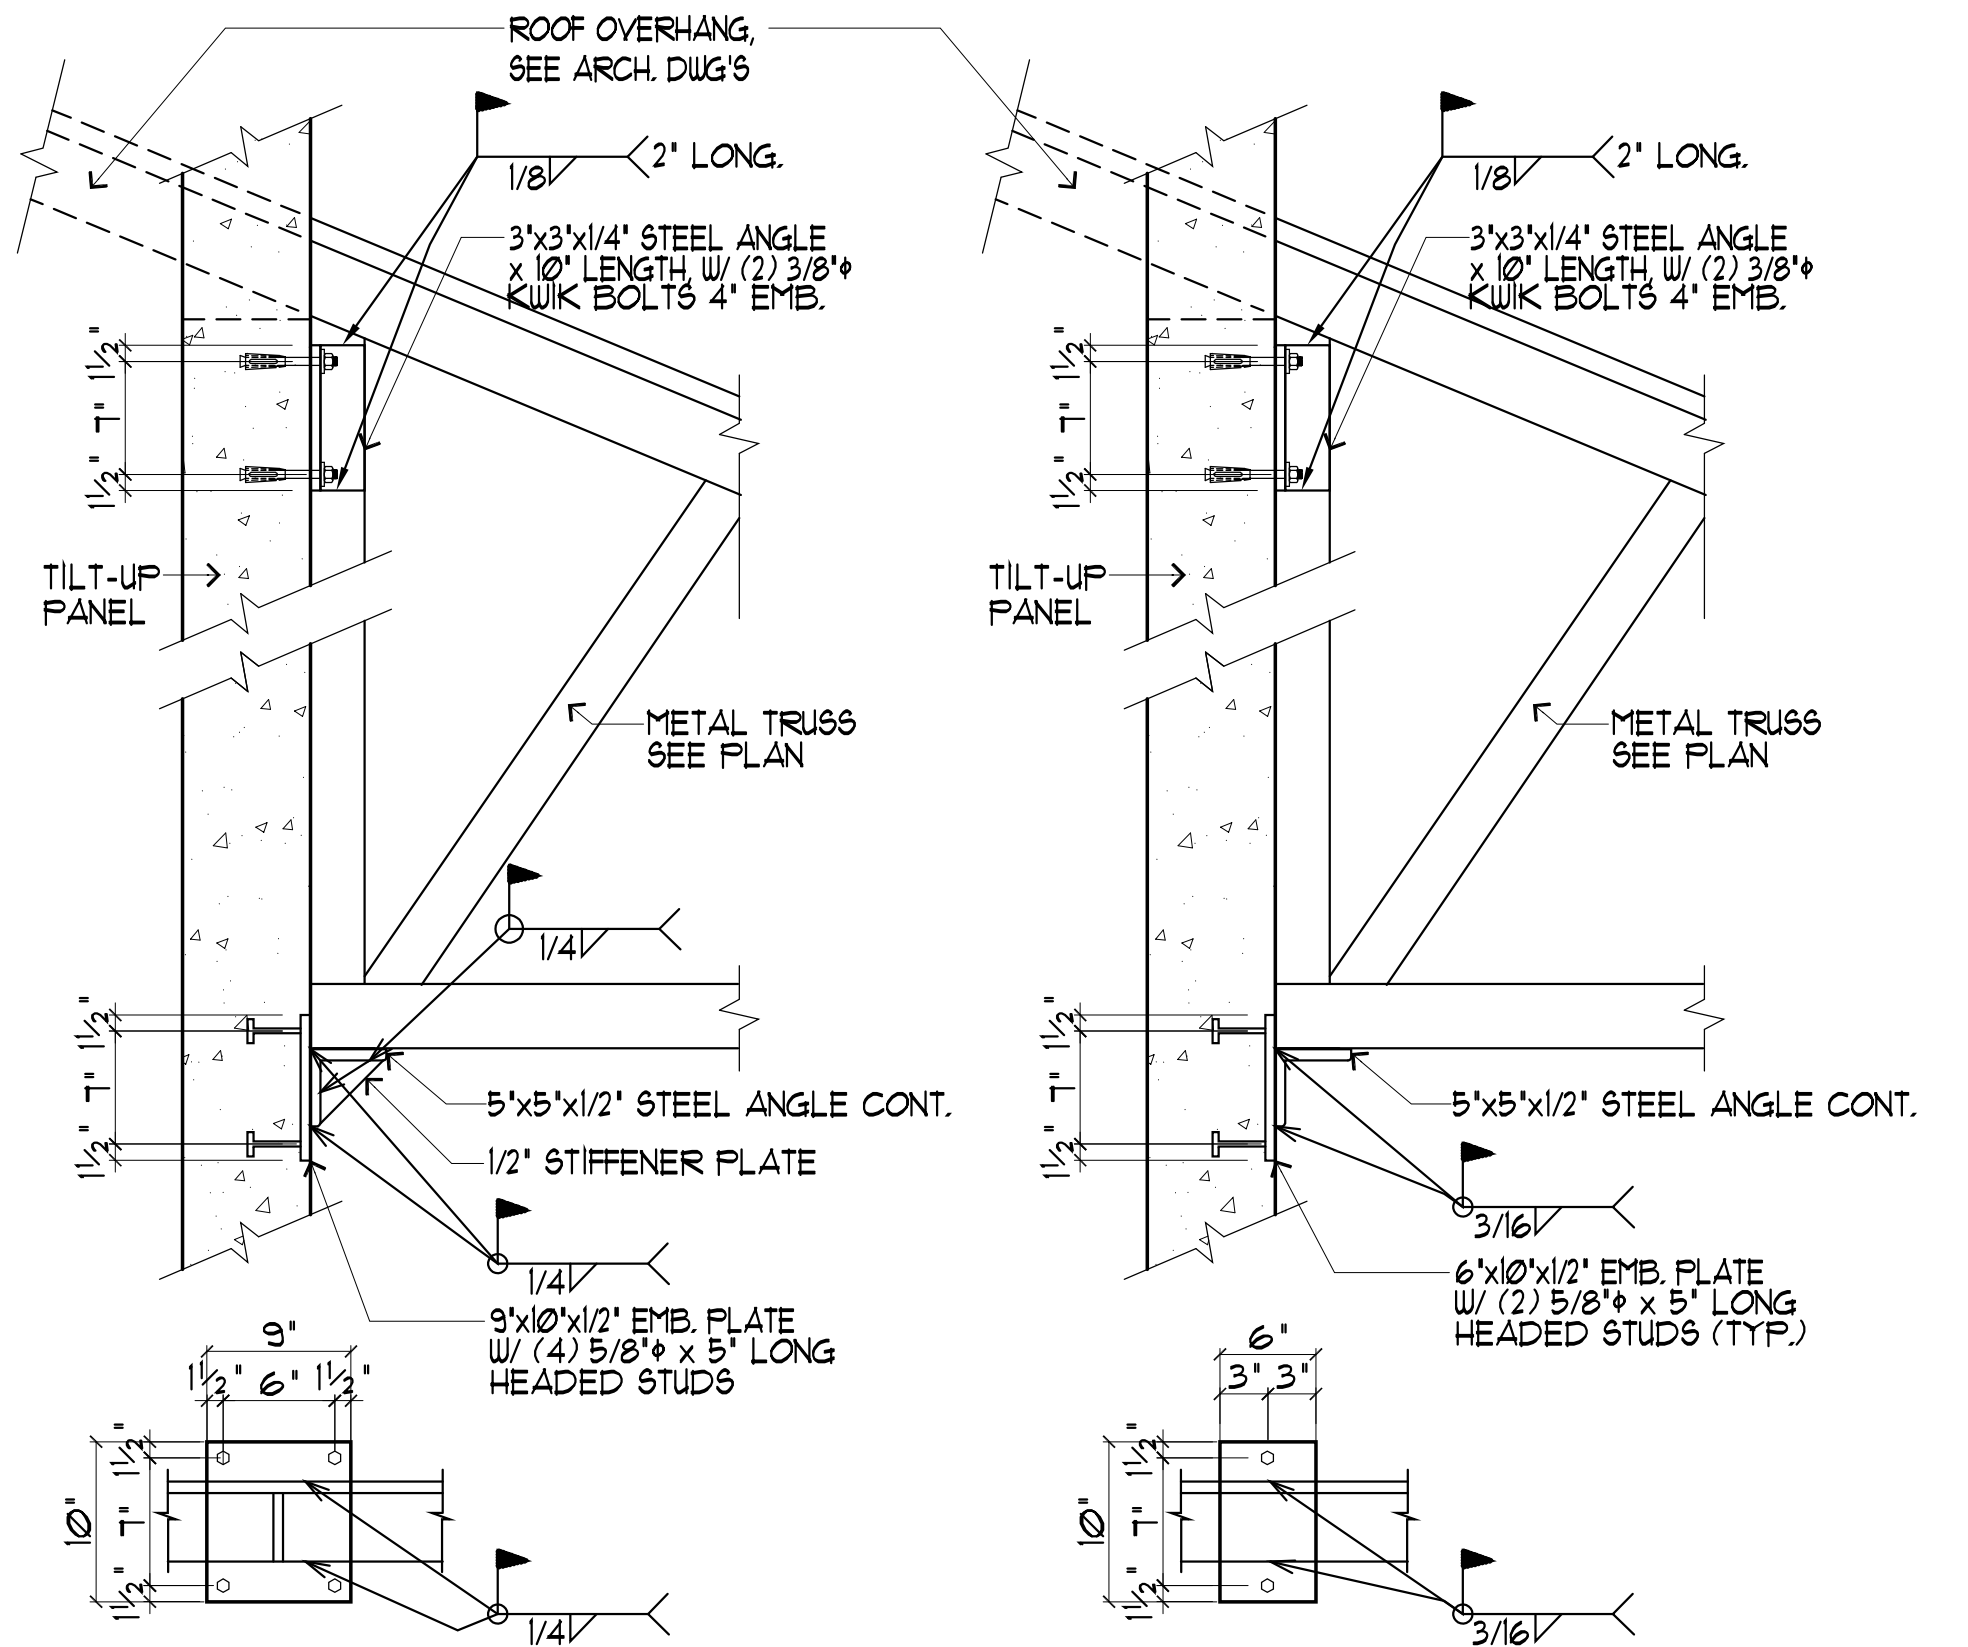

DETAIL

SCALE: N.T.S.

DETAIL

SCALE: N.T.S.

CONSULTANT INFO:

D.D.A. ENGINEERS, P.A.
CONSULTING
4930 S.W. 74TH Court
Miami, Florida, 33155
Phone: (305) 666-0711
Fax: (305) 666-6269
www.ddaeng.com
2019-42-A




NEW ELEMENTARY SCHOOL (K-5)

VENETIAN PARC WEST

SOUTHWEST 157th AVENUE and 174th STREET
MIAMI, FL. 33187

MDCPS PROJECT No. 01892600

KEY PLAN

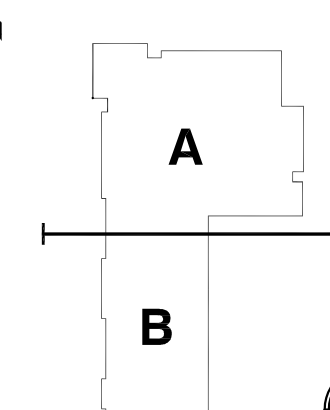

CONSULTANT INFO:

ADA M. ALBARRA, P.E.


RODRIGUEZ ARCHITECTS INCORPORATED
3121 PONCE DE LEON BLVD. STE 100
CORAL GABLES, FL. 33134
TEL: (305) 448-3373
FAX: (305) 448-3374
A A C -- 0 0 1 9 3 3

RAI


REVISIONS:

BEAM SCHEDULES AND DETAILS



SCALE: AS NOTED
ISSUE DATE: 10.11.19
PROJECT NO: 1906
SHEET: **S-303**

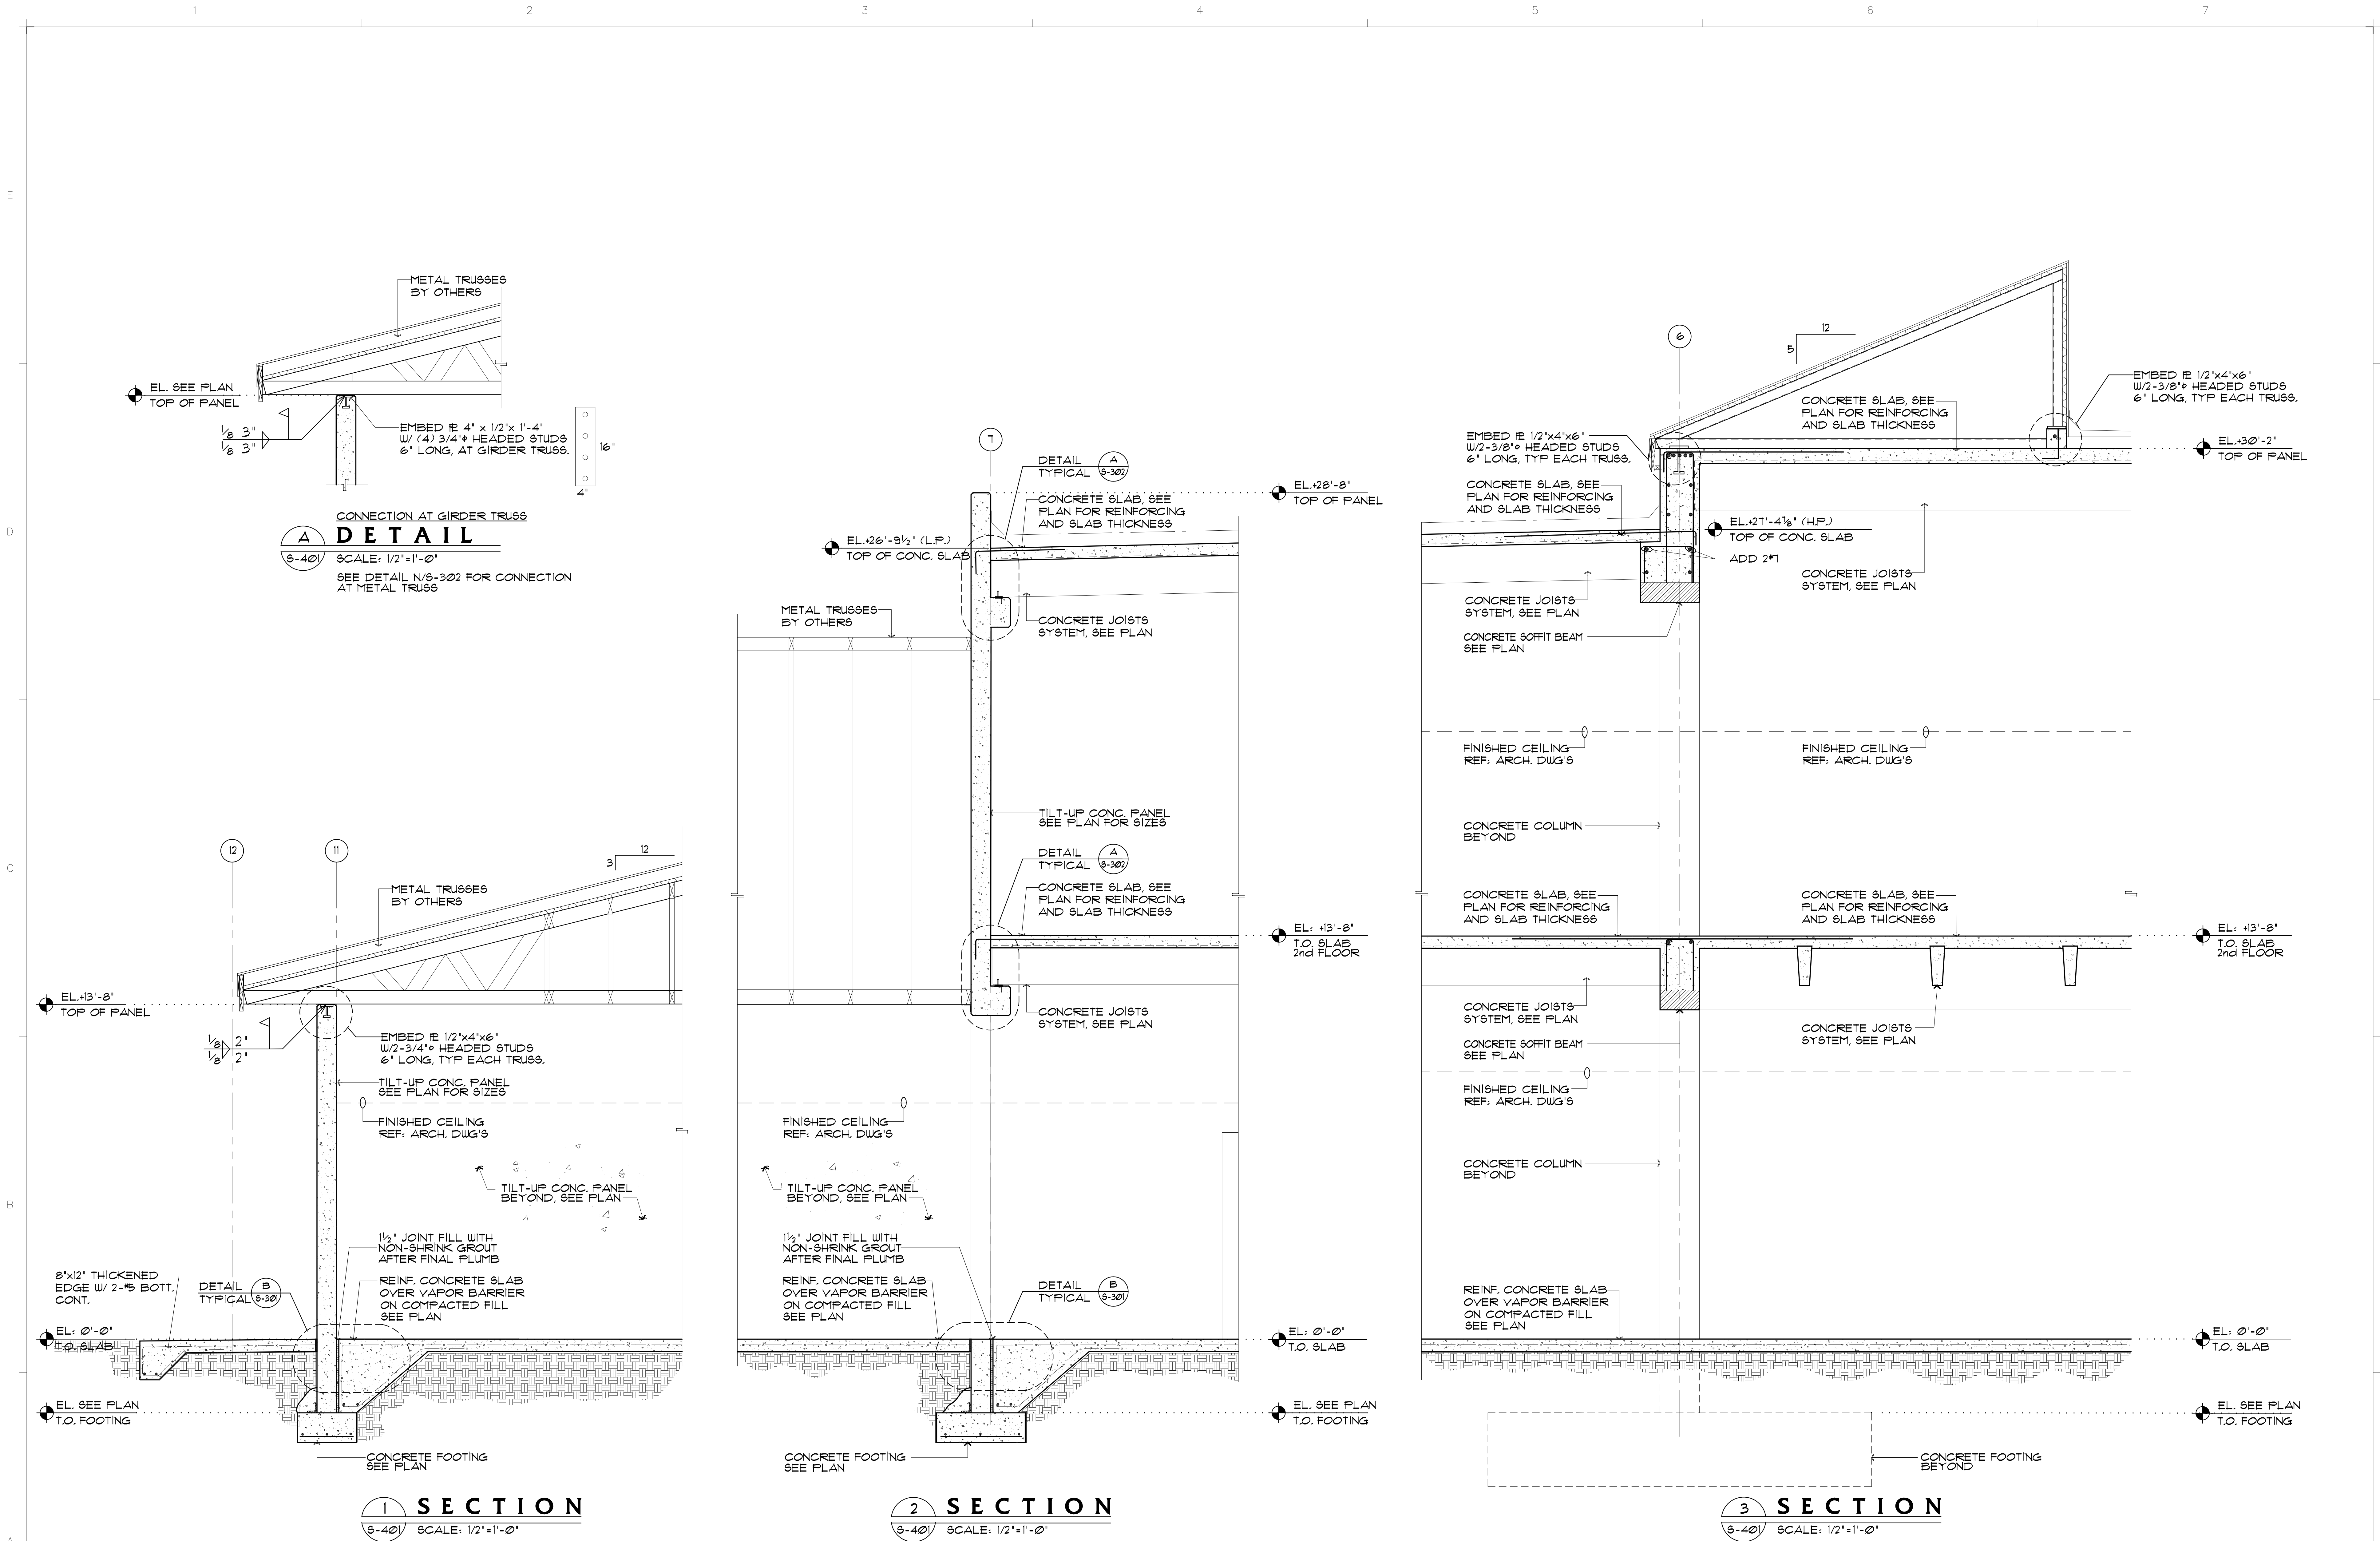

CONSULTANT INFO
D.D.A. ENGINEERS, P.A.
CONSULTING
4930 S.W. 74TH Court
Miami, Florida, 33155
Phone: (305)666-0711
Fax: (305)666-6269
www.ddaeng.com
2019-42-A

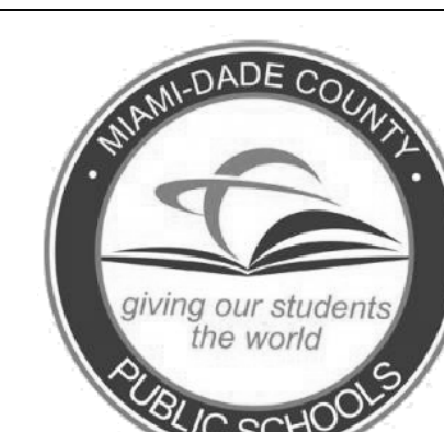

NEW ELEMENTARY SCHOOL (K-5)
VENETIAN PARC WEST
SOUTHWEST 157th AVENUE and 174th STREET
MIAMI, FL. 33187
MDCPS PROJECT No. 01892600

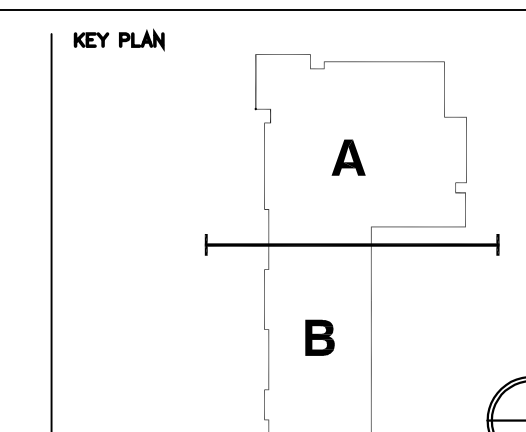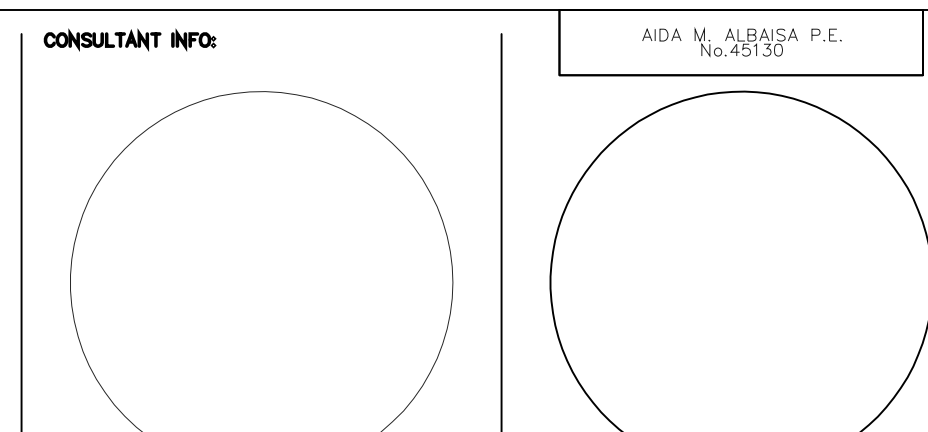


RODRIGUEZ
ARCHITECTS
INCORPORATED
2121 PONCE DE LEON BLVD. STE 1010
CORAL GABLES, FL. 33134
TEL: (305) 448-3373
FAX: (305) 448-3374
A A C -- 0 0 1 9 3 3







REVISIONS	


SECTIONS	

SCALE AS NOTED
ISSUE DATE: 10.11.19
PROJECT NO: 1906
SHEET: **S-401**

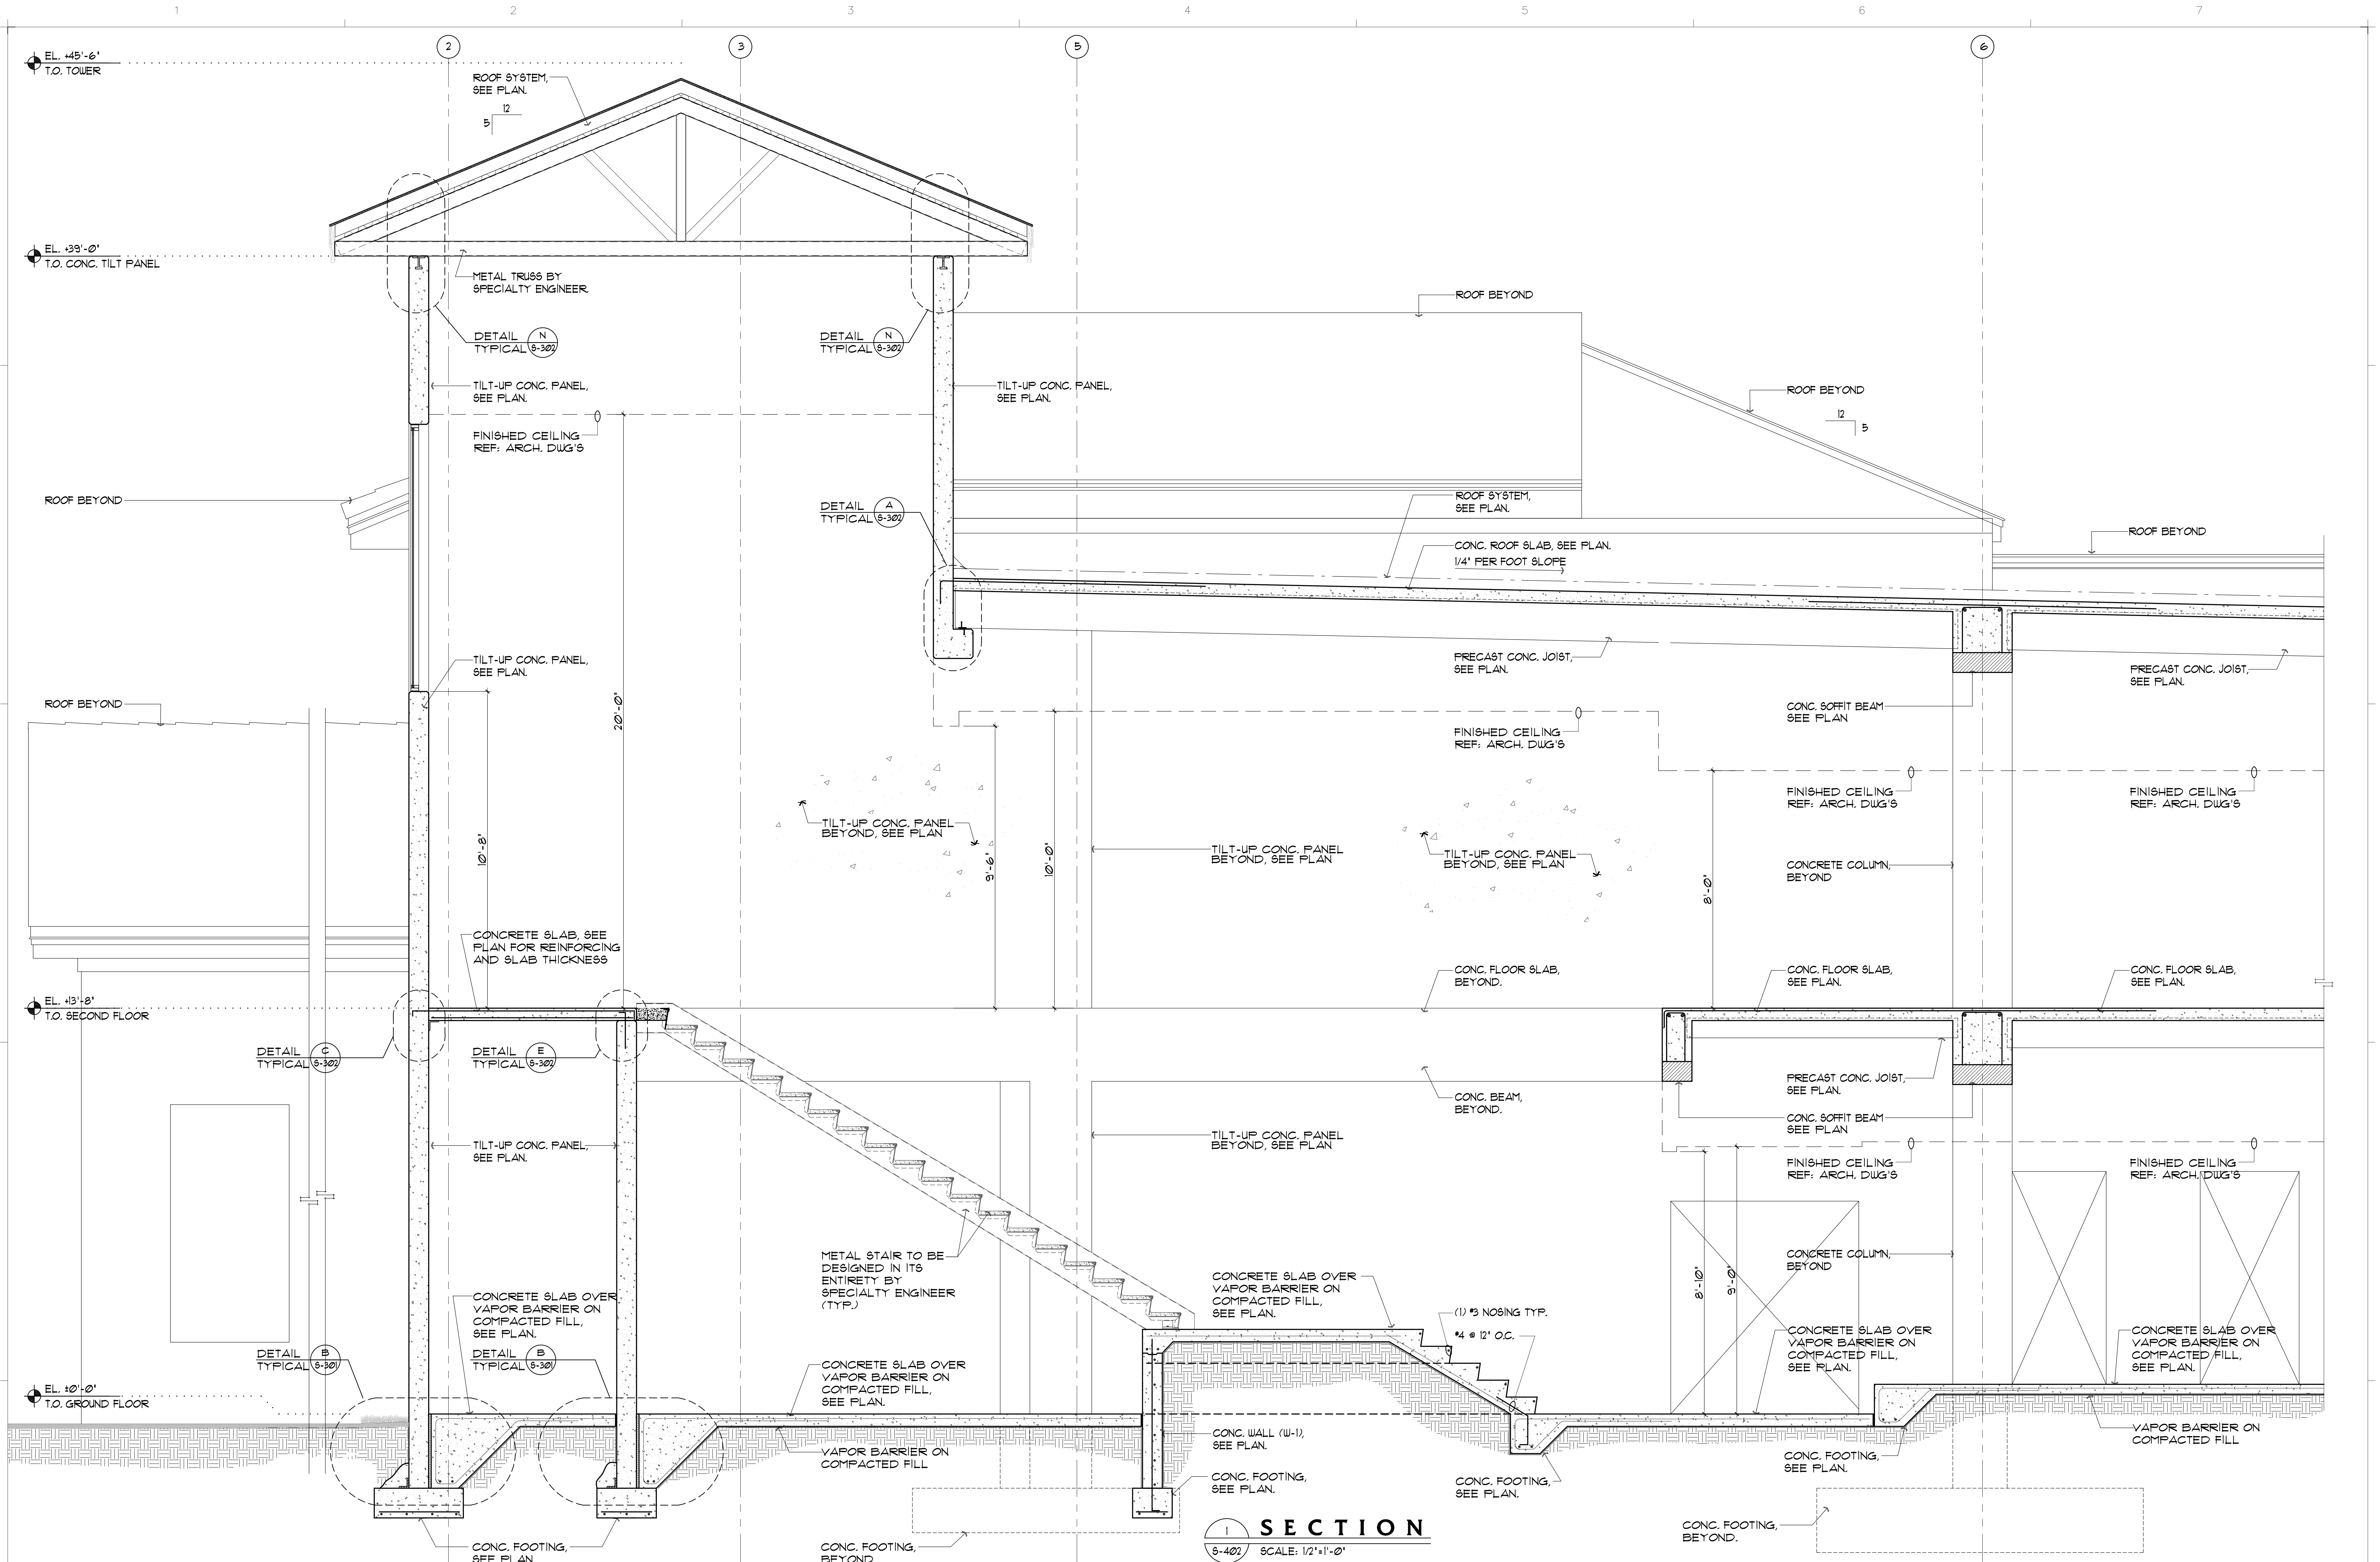

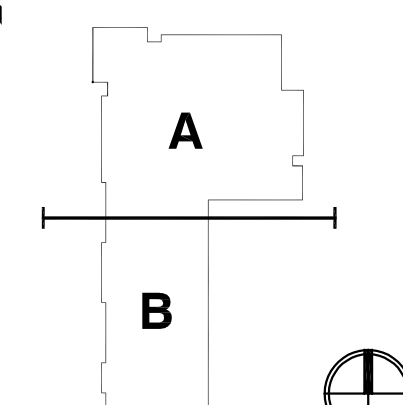CONSULTANT INFO D.D.A. ENGINEERS, P.A. CONSULTING 4930 S.W. 74TH Court Miami, Florida, 33155 Phone: (305)666-0711 Fax: (305)666-6269 www.ddaeng.com 2019-42-A		 NEW ELEMENTARY SCHOOL (K-5) VENETIAN PARC WEST SOUTHWEST 157th AVENUE and 174th STREET MIAMI, FL. 33187 MDCPS PROJECT No. 01892600	KEY PLAN 	CONSULTANT INFO ADA M. ALBARRA P.E. NO. 6130		RODRIGUEZ ARCHITECTS INCORPORATED 2121 PONCE DE LEON BLVD. STE 1010 CORAL GABLES, FL. 33134 TEL: (305) 448-3373 FAX: (305) 448-3374 A A C -- 0 0 1 9 3 3		REVISIONS 1 2 3 4 5 6 7 8 9 10	DRAWING TITLE: SECTIONS SCALE AS NOTED ISSUE DATE: 10.11.19 PROJECT NO: 1906 SHEET: S-402
DESIGNED BY: LR.	DRAWN BY: C.V.								

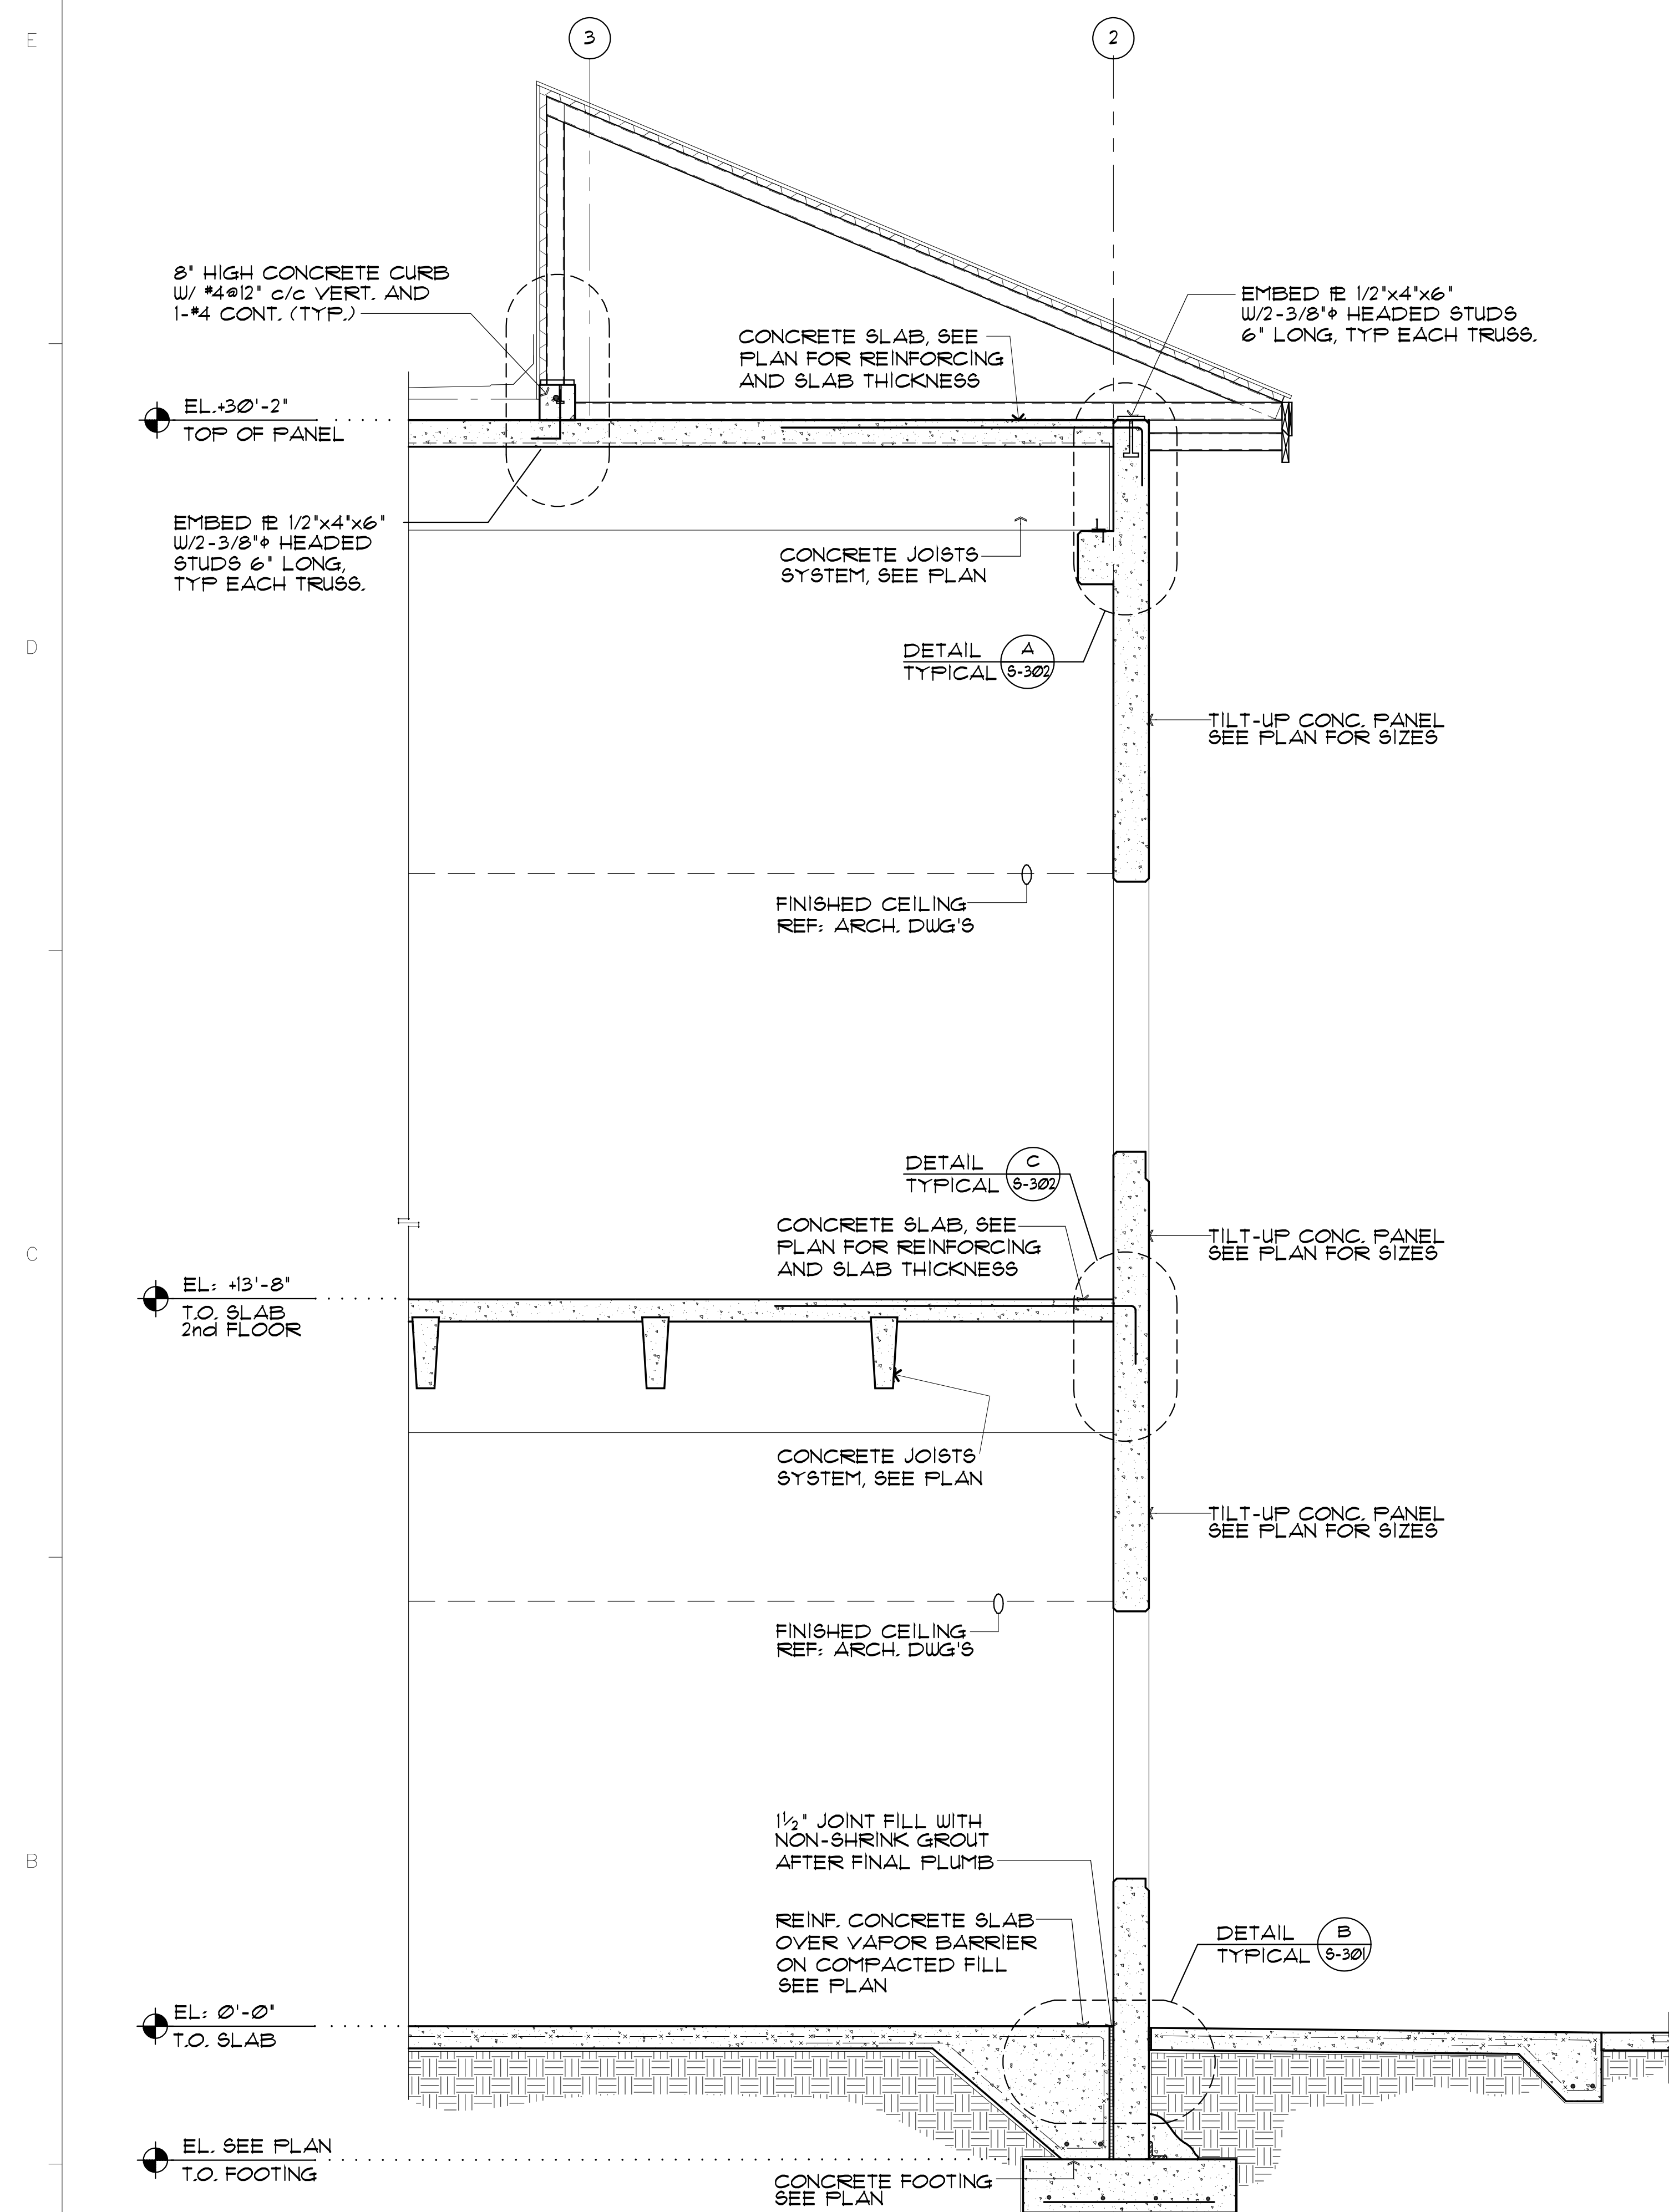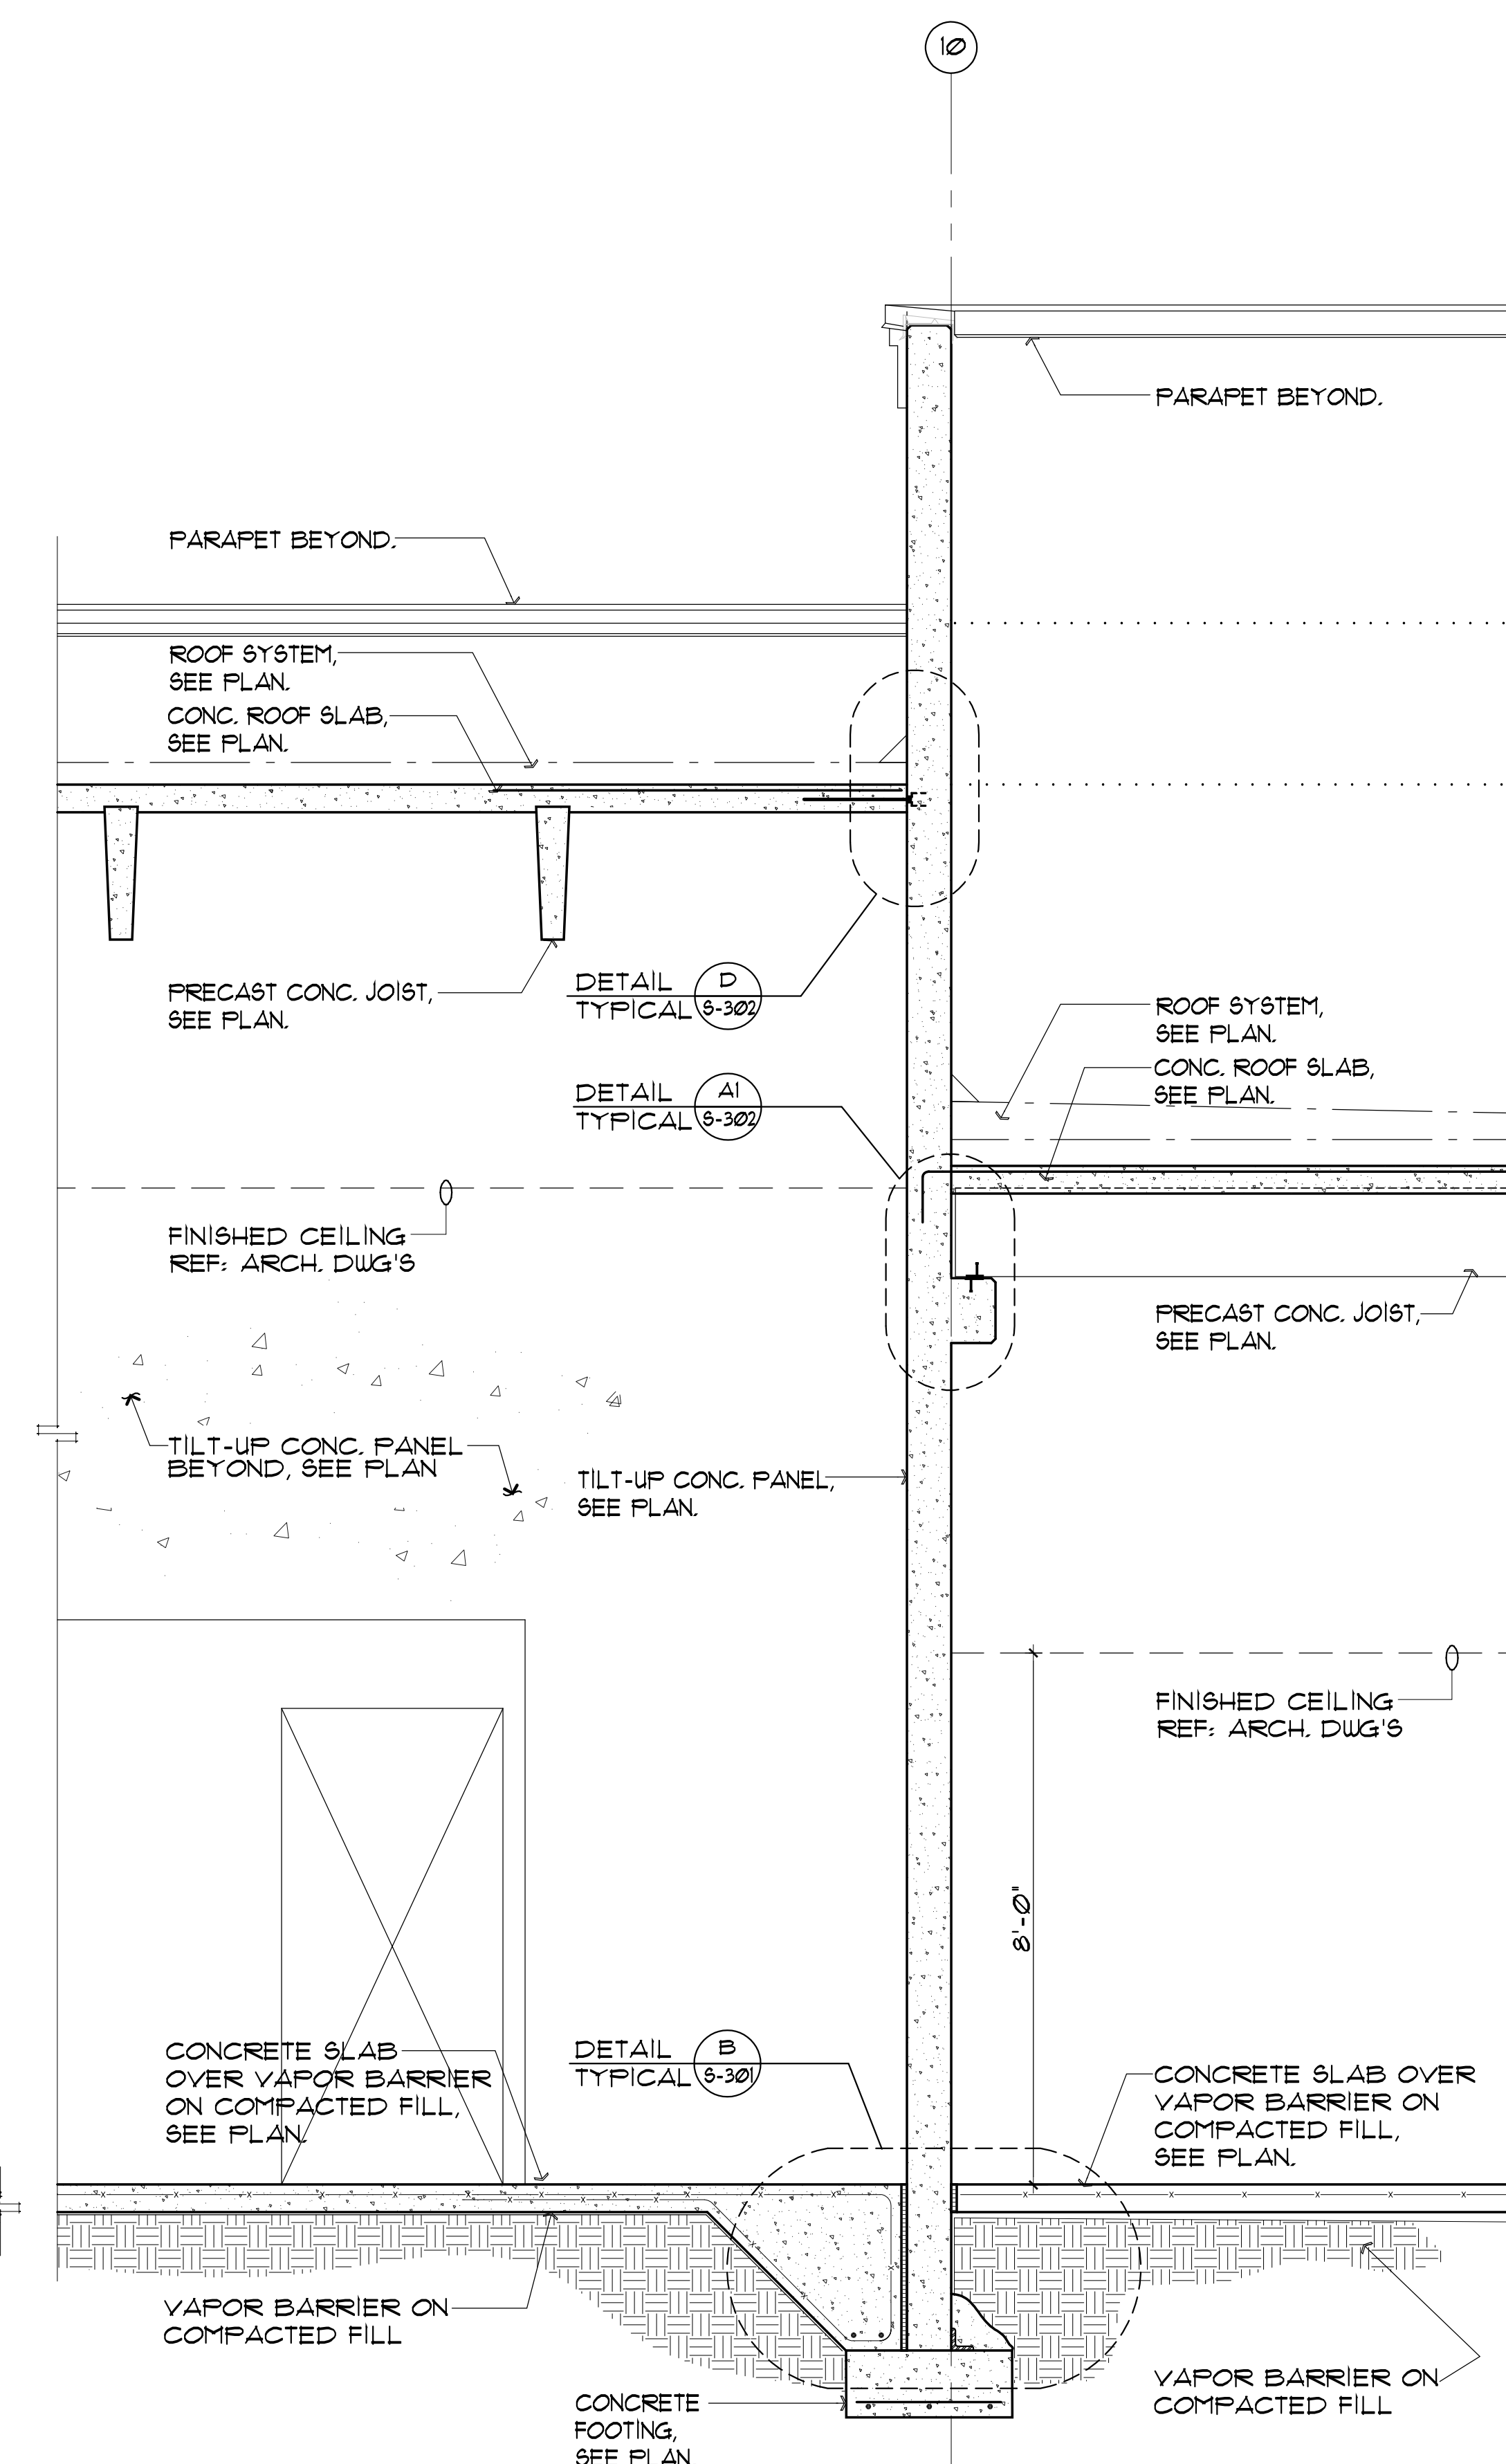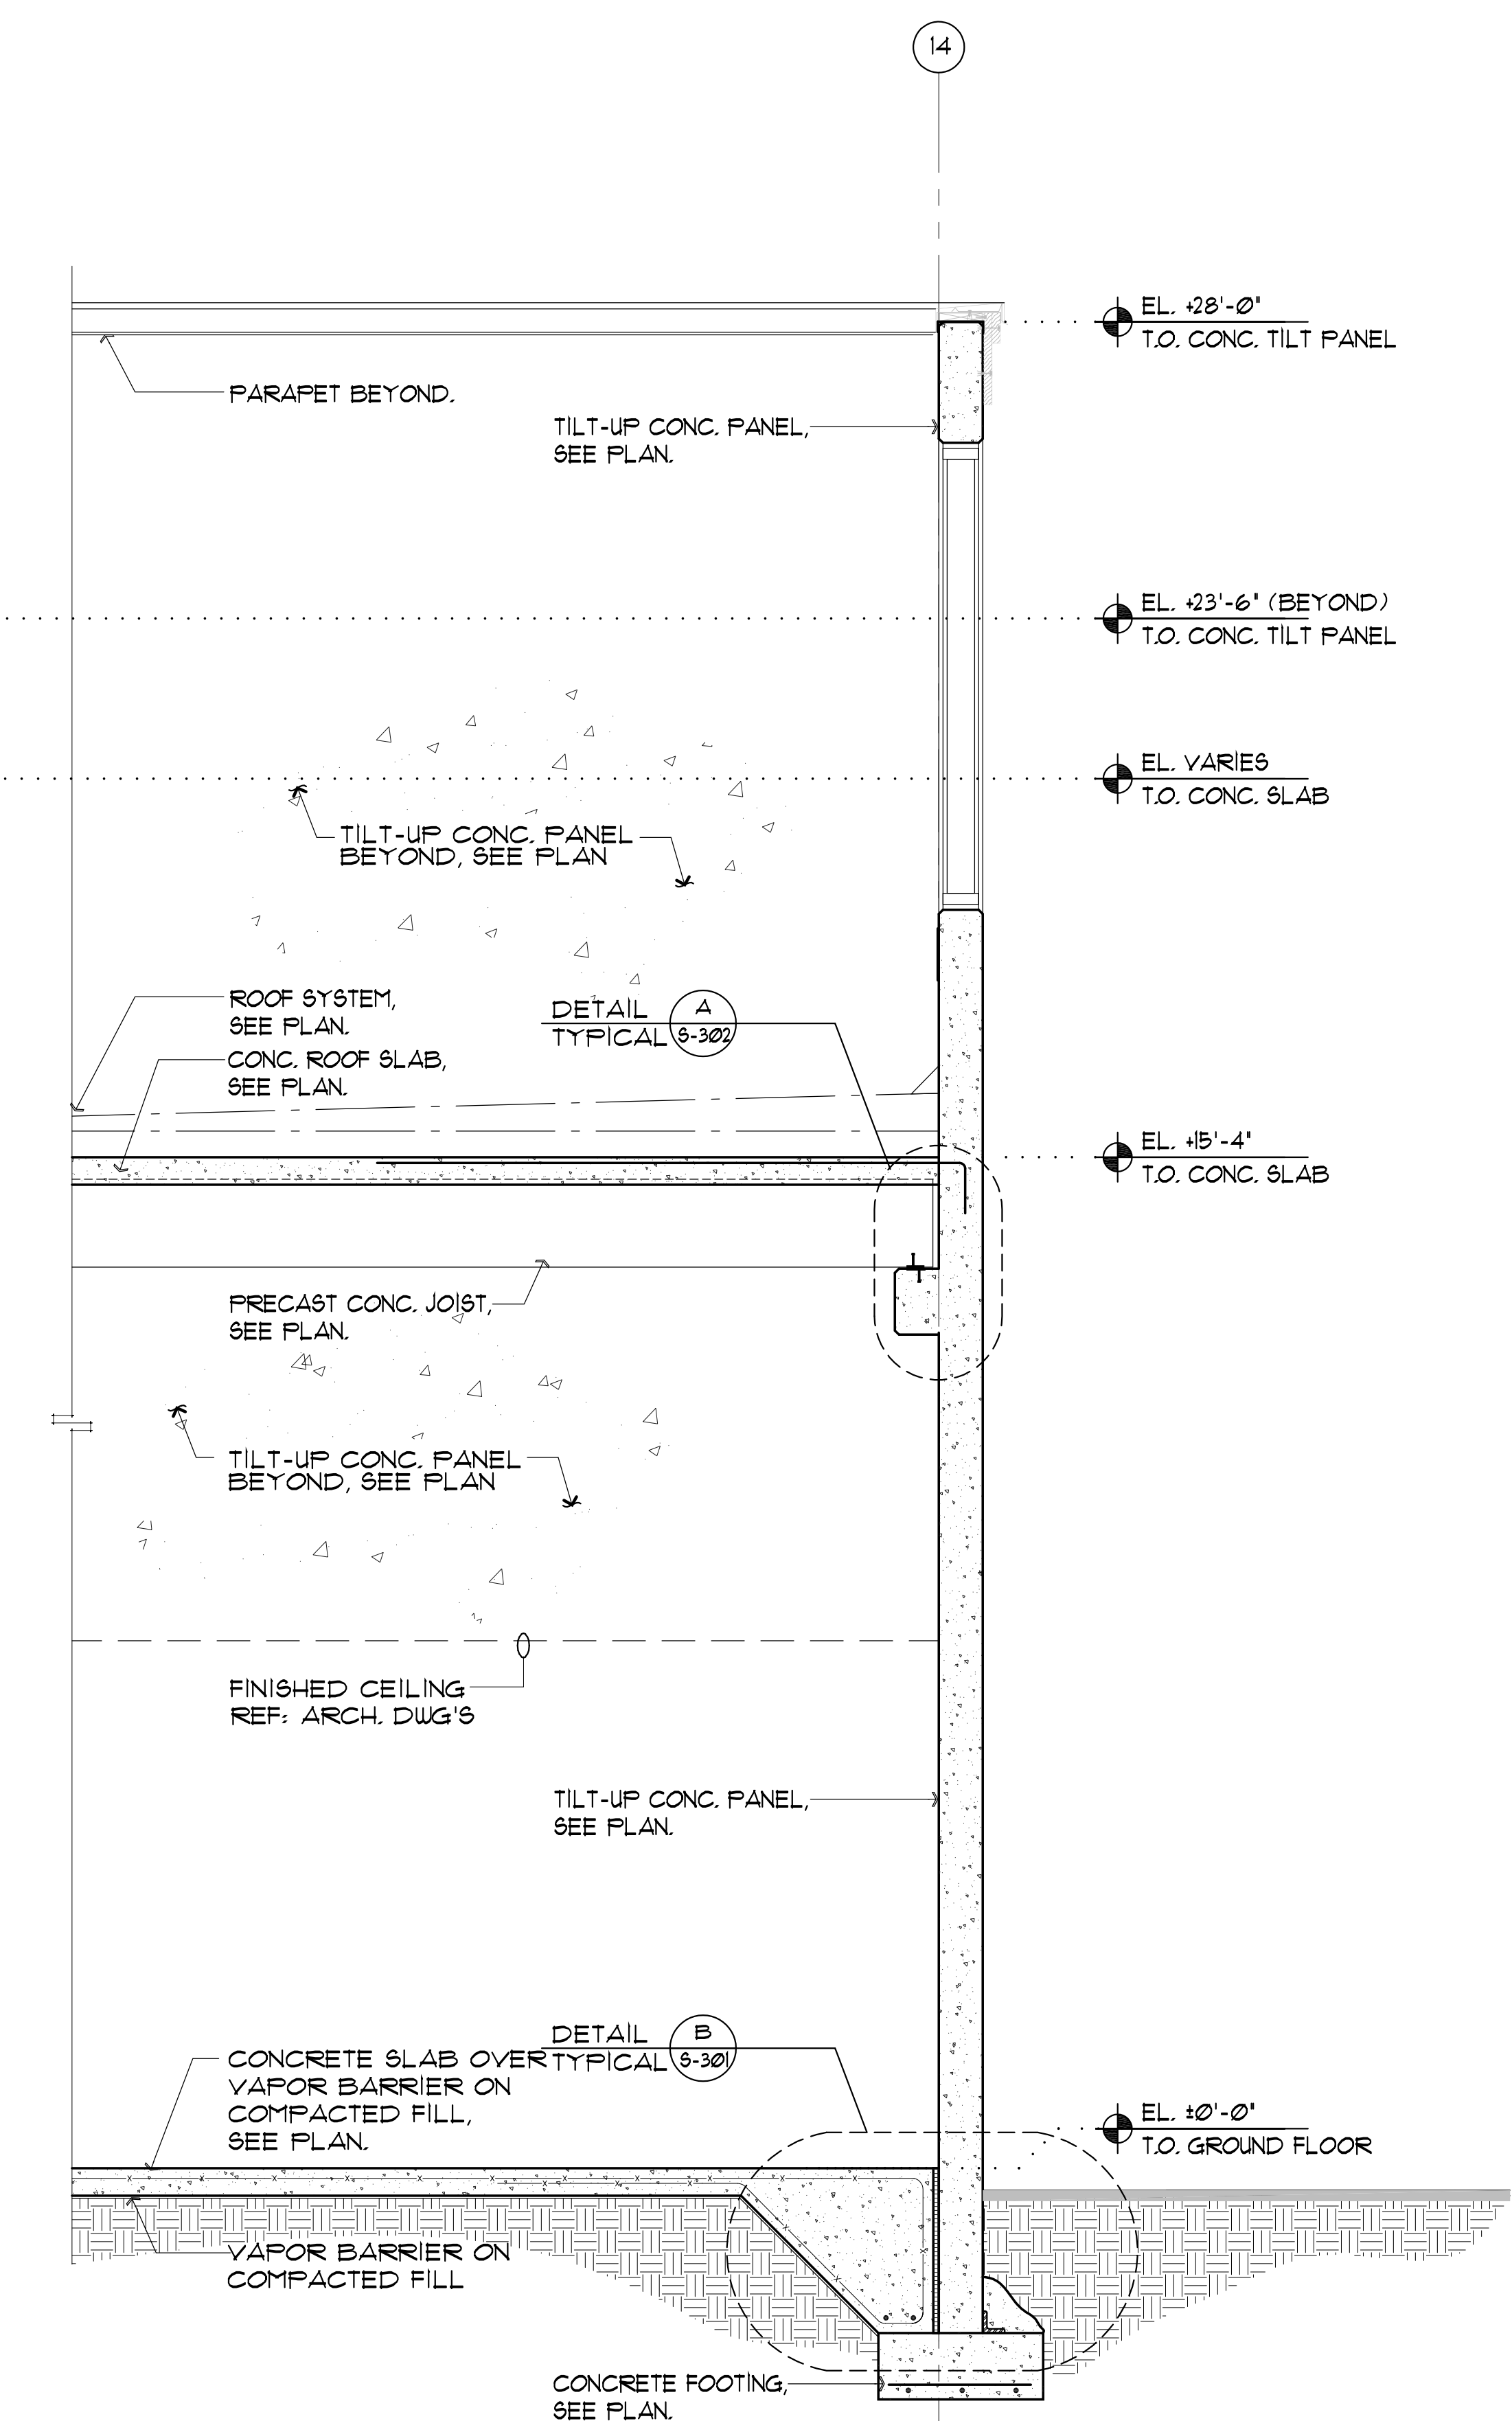

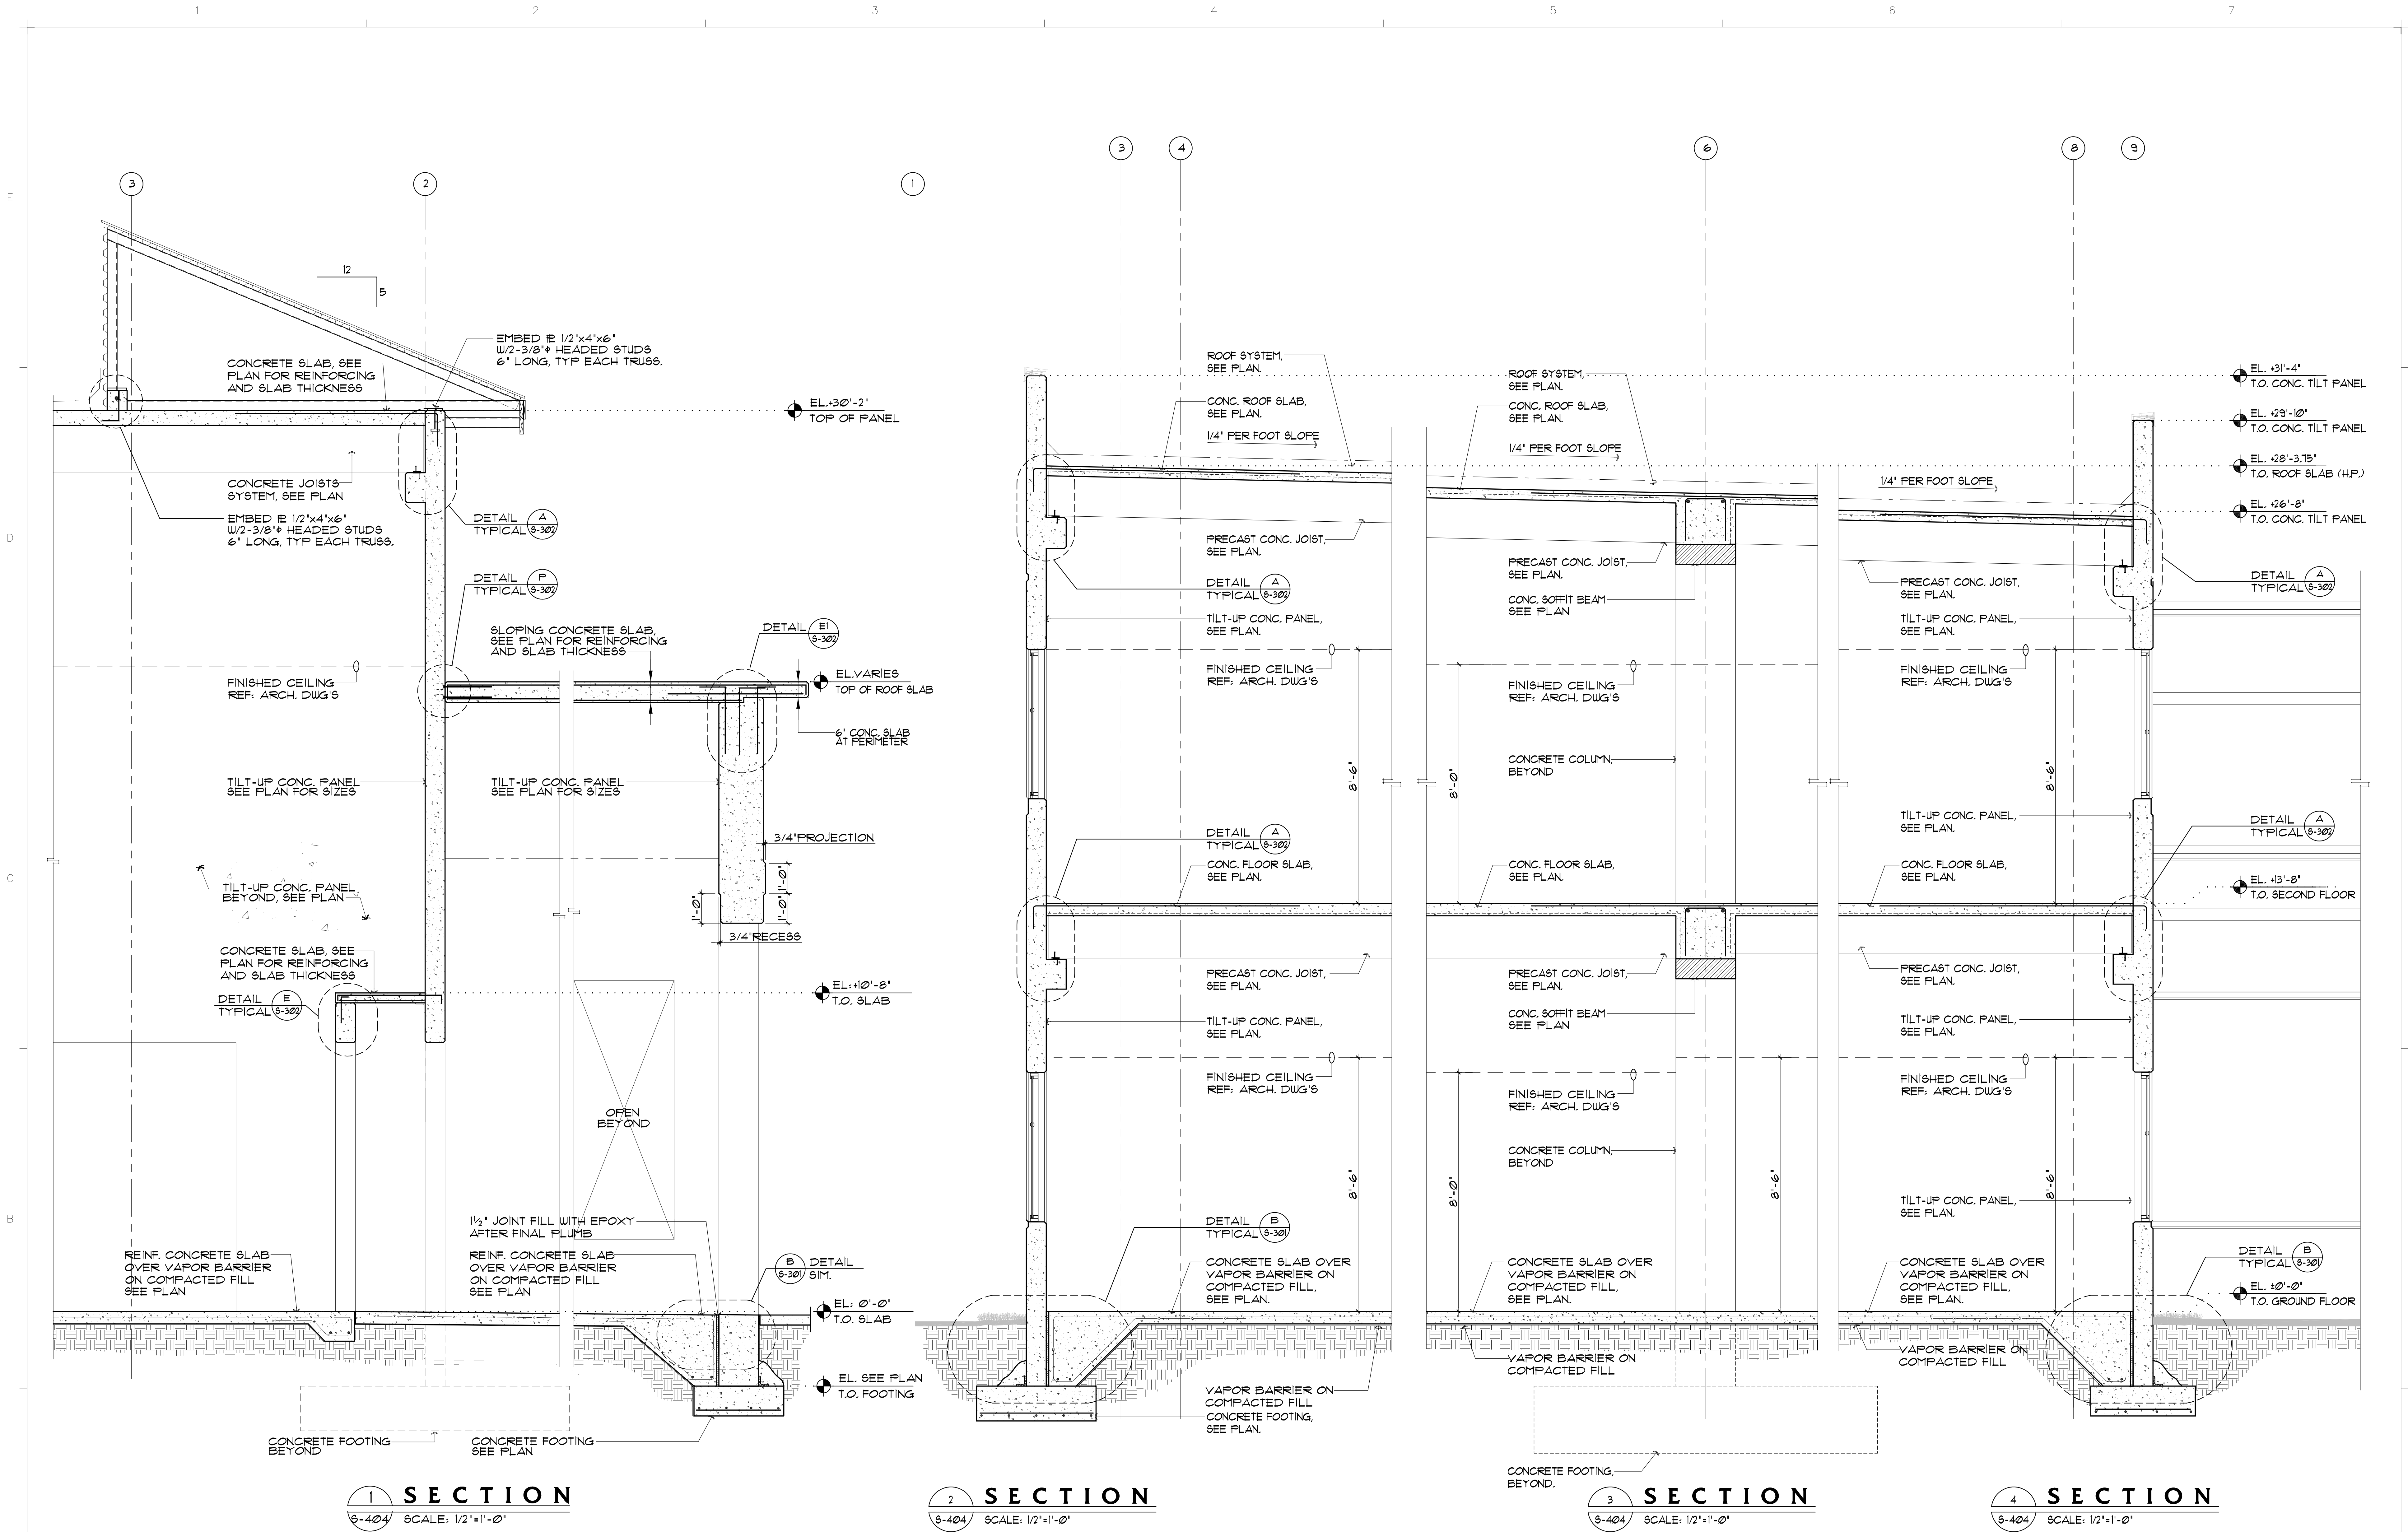

1 SECTION
5'-40" SCALE: 1/2"=1'-0"

2 SECTION
5'-40" SCALE: 1/2"=1'-0"

3 SECTION
5'-40" SCALE: 1/2"=1'-0"

4 SECTION
5'-40" SCALE: 1/2"=1'-0"

CONSULTANT INFO

DDA ENGINEERS, P.A.
CONSULTING

4930 S.W. 74TH Court
Miami, Florida, 33155
Phone: (305)666-0711
Fax: (305)666-6269
www.ddaeng.com
2019-42-A

NEW ELEMENTARY SCHOOL (K-5)
VENETIAN PARC WEST
SOUTHWEST 157th AVENUE and 174th STREET
MIAMI, FL. 33187
MDCPS PROJECT No. 01892600

KEY PLAN

CONSULTANT INFO


ADA M. ALBARRA P.E.
NO. 6150

RODRIGUEZ ARCHITECTS INCORPORATED
2121 PONCE DE LEON BLVD. STE 1010
CORAL GABLES, FL. 33134
TEL: (305) 448-3373
FAX: (305) 448-3374
A A C -- 0 0 1 9 3 3

REVISIONS

NO.	DESCRIPTION


DRAWING TITLE:
SECTIONS
SCALE AS NOTED
ISSUE DATE:
10.11.19
PROJECT NO.
1906
SHEET:
S-404

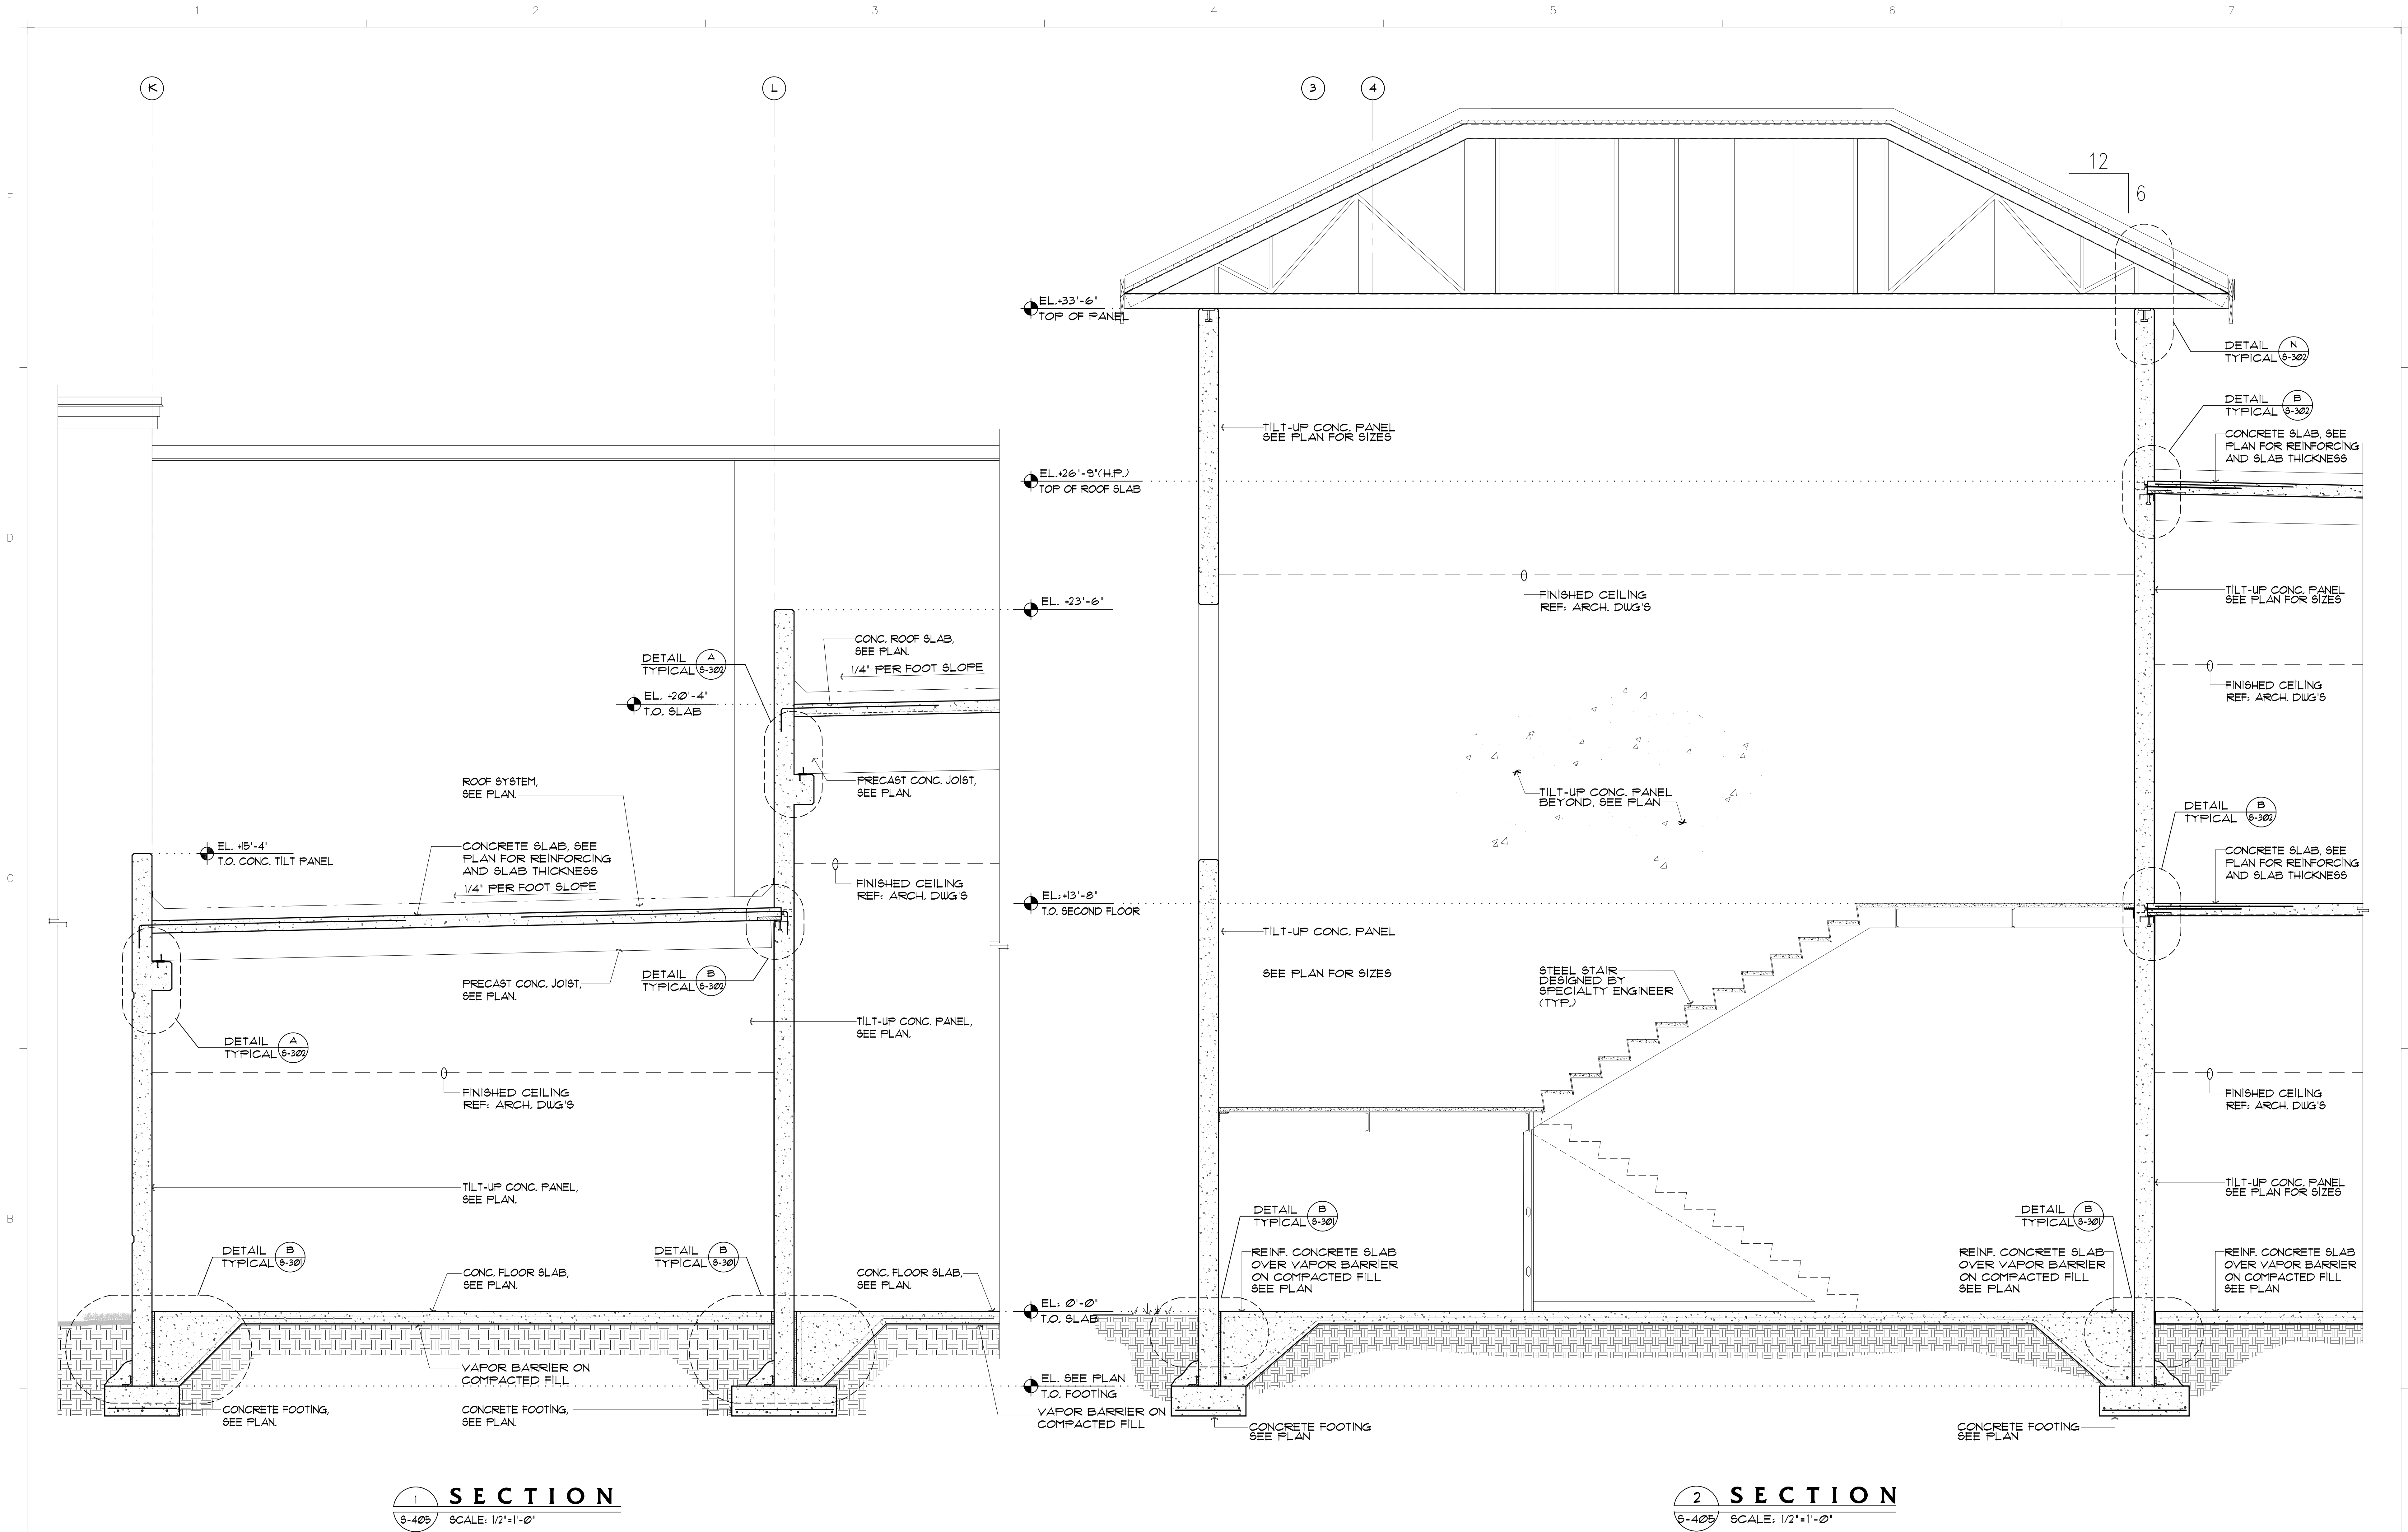

1 SECTION
S-405 SCALE: 1/2"=1'-0"

2 SECTION
S-405 SCALE: 1/2"=1'-0"



CHECKED BY: LR.	DRAWN BY: C.V.	 D.D.A. ENGINEERS, P.A. CONSULTING 4930 S.W. 74TH COURT Miami, Florida, 33155 Phone: (305) 666-0711 Fax: (305) 666-6269 www.ddaeng.com 2019-42-A	 MIAMI-DADE COUNTY PUBLIC SCHOOLS giving our students the world	NEW ELEMENTARY SCHOOL (K-5) VENETIAN PARC WEST SOUTHWEST 157th AVENUE and 174th STREET MIAMI, FL. 33187 MDCPS PROJECT No. 01892600		KEY PLAN 	CONSULTANT INFO: 	ADA M. ALBARRA, P.E. No. 01307	RODRIGUEZ ARCHITECTS INCORPORATED 2121 PONCE DE LEON BLVD. STE 1010 CORAL GABLES, FL. 33134 TEL: (305) 448-3373 FAX: (305) 448-3374 A A C -- 0 0 1 9 3 3		REVISIONS: 	DRAWING TITLE: SECTIONS
				ISSUE DATE: 10.11.19	PROJECT NO: 1906							SHEET: S-405

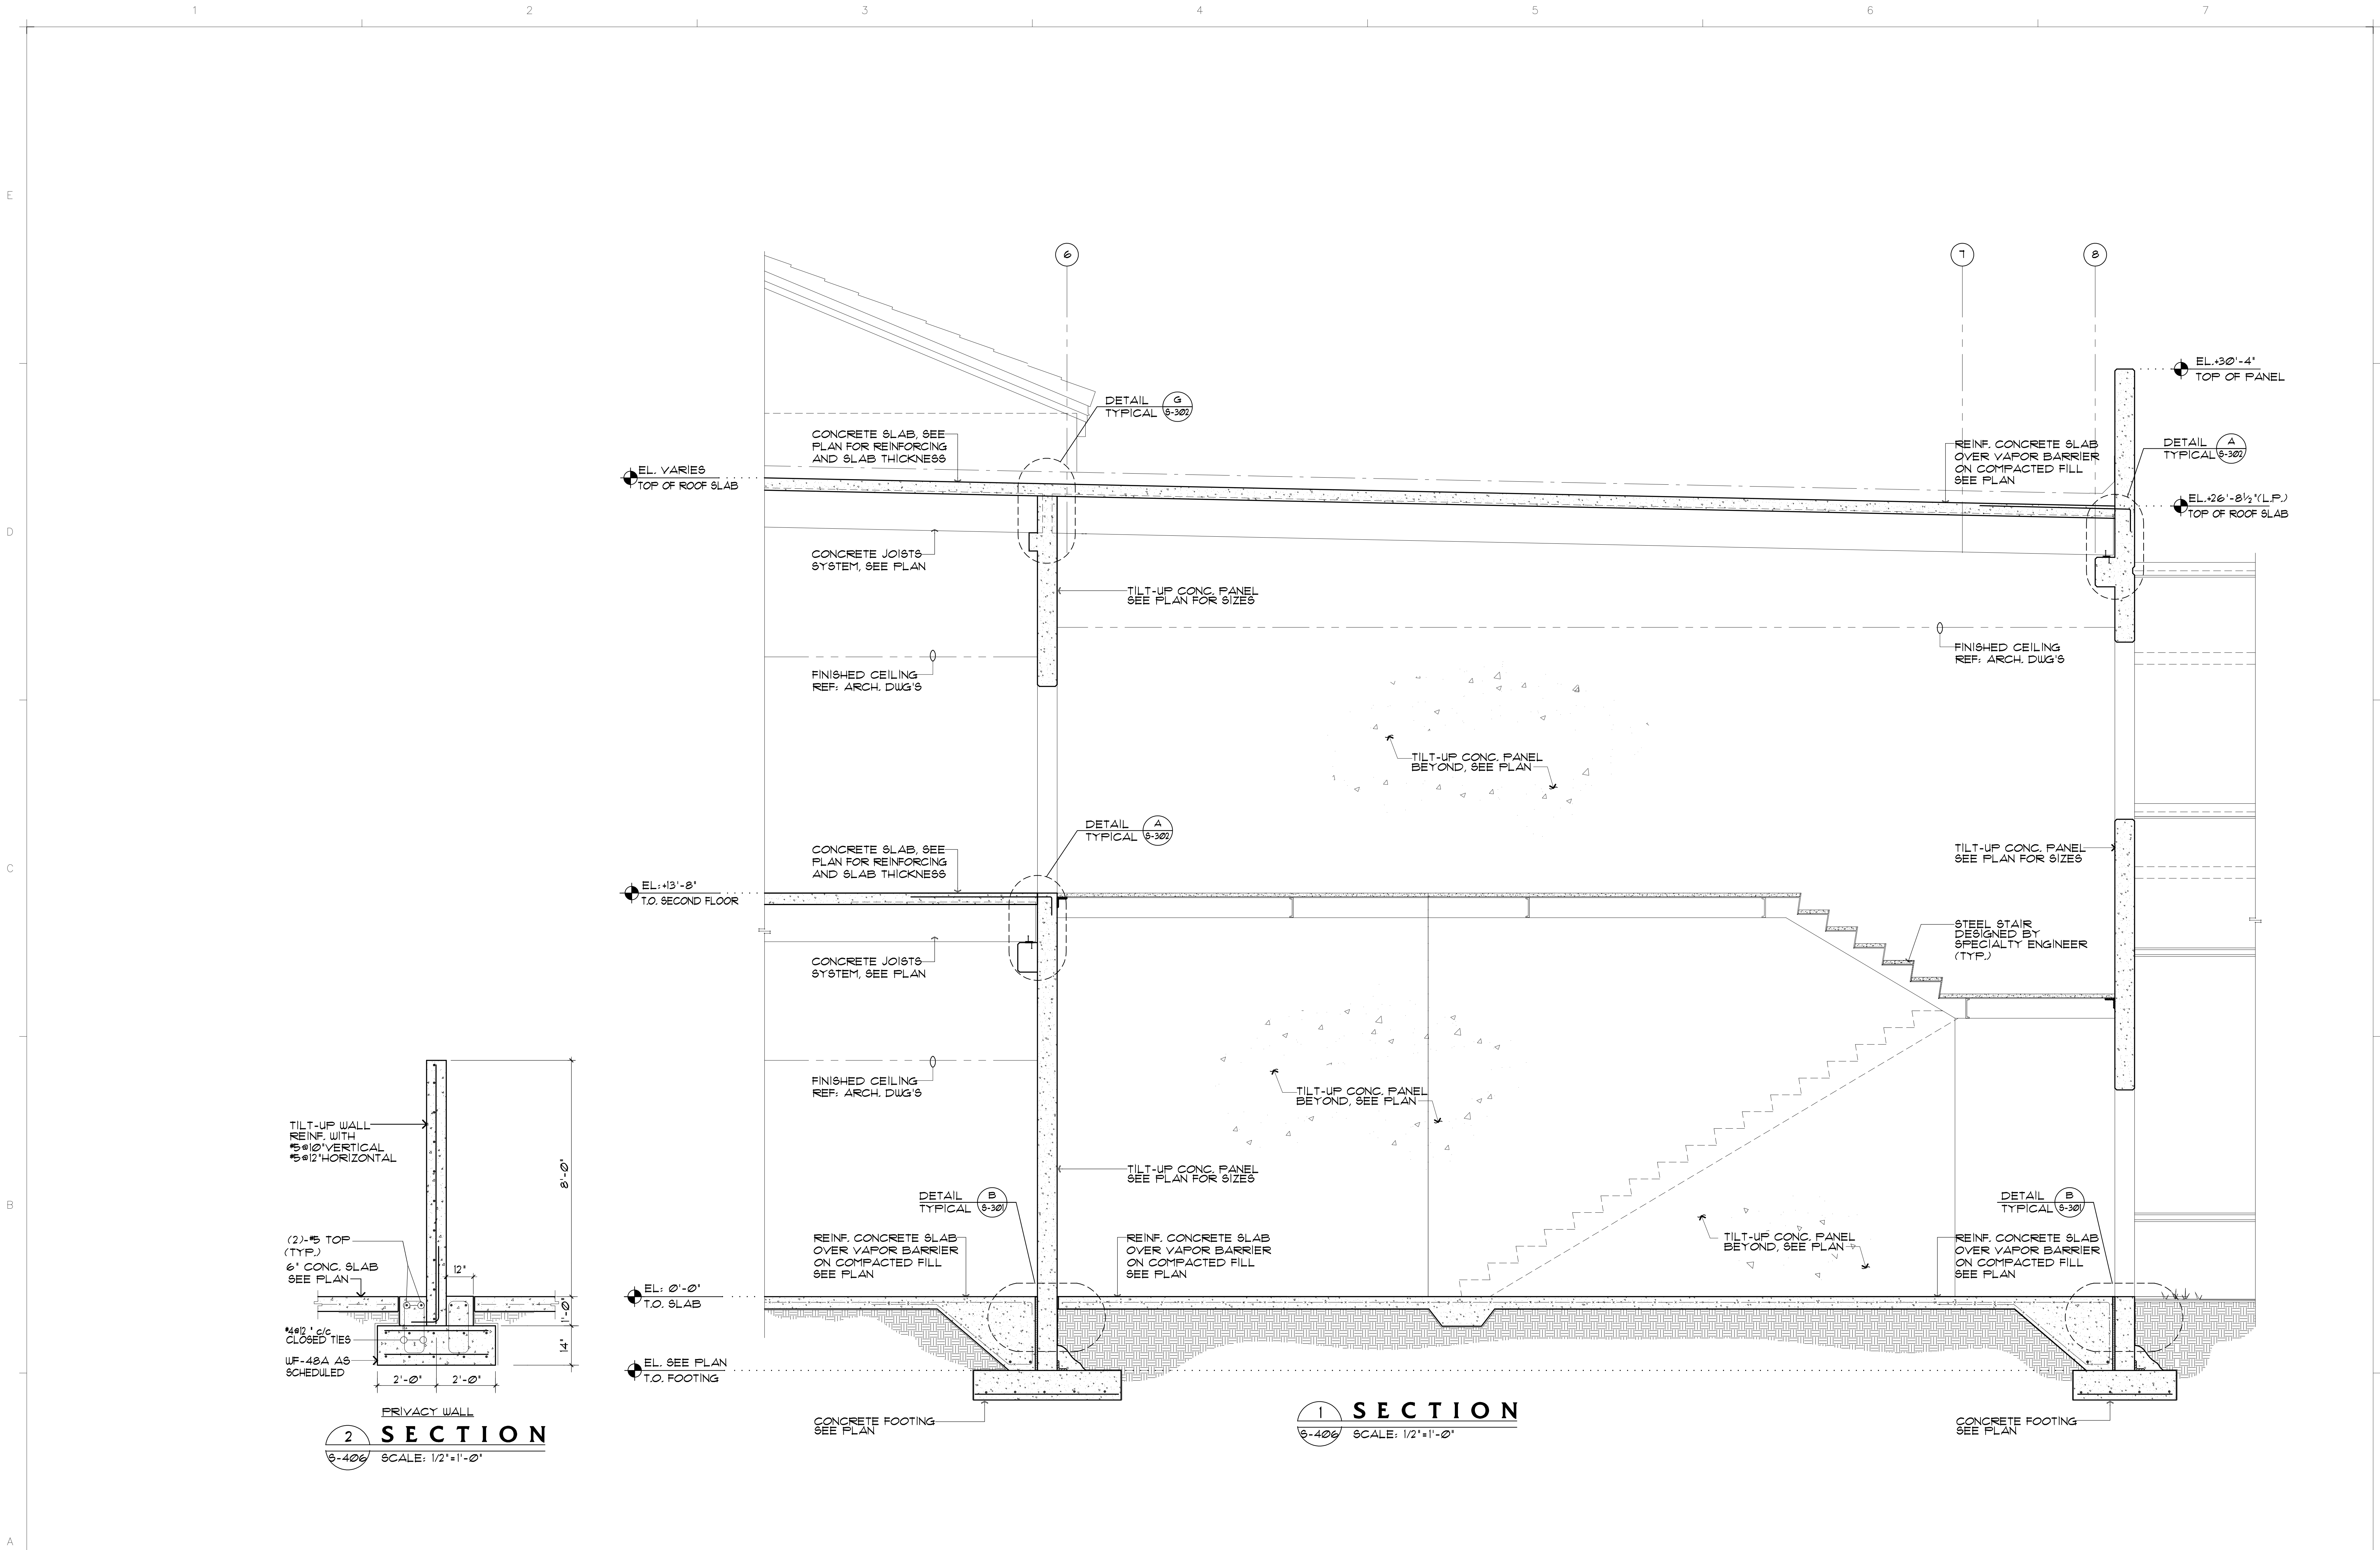


CHECKED BY: LR.		DRAWN BY: C.V.	
---------------------------	--	--------------------------	--


CONSULTANT INFO:	
 D.D.A. ENGINEERS, P.A. CONSULTING	4930 S.W. 74TH Court Miami, Florida, 33155 Phone: (305) 666-0711 Fax: (305) 666-6269 www.ddaeng.com 2019-42-A

 MIAMI-DADE COUNTY PUBLIC SCHOOLS giving our students the world	NEW ELEMENTARY SCHOOL (K-5) VENETIAN PARC WEST SOUTHWEST 157th AVENUE and 174th STREET MIAMI, FL. 33187 MDCPS PROJECT No. 01892600
--	--

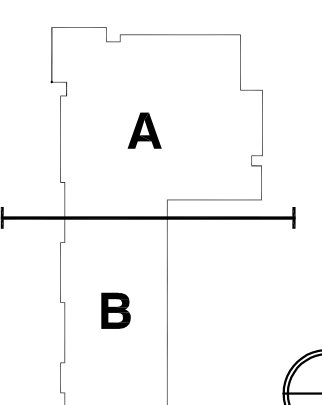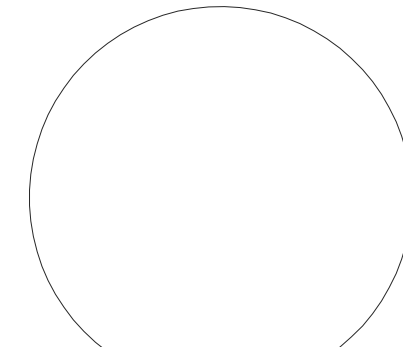KEY PLAN 	CONSULTANT INFO: 	ADA M. ALBESA P.E. No. 0130
--	--	---------------------------------------

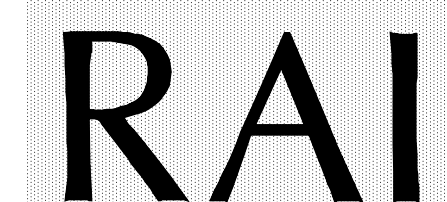RODRIGUEZ ARCHITECTS INCORPORATED 2121 PONCE DE LEON BLVD. STE 1010 CORAL GABLES, FL. 33134 TEL: (305) 448-3373 FAX: (305) 448-3374 A A C -- 0 0 1 9 3 3		REVISIONS: _____ _____ _____ _____ _____ _____ _____ _____ _____ _____
--	---	---

ISSUE TITLE: SECTIONS	
SCALE AS NOTED	
ISSUE DATE: 10.11.19	PROJECT NO: 1906
SHEET: S-406	

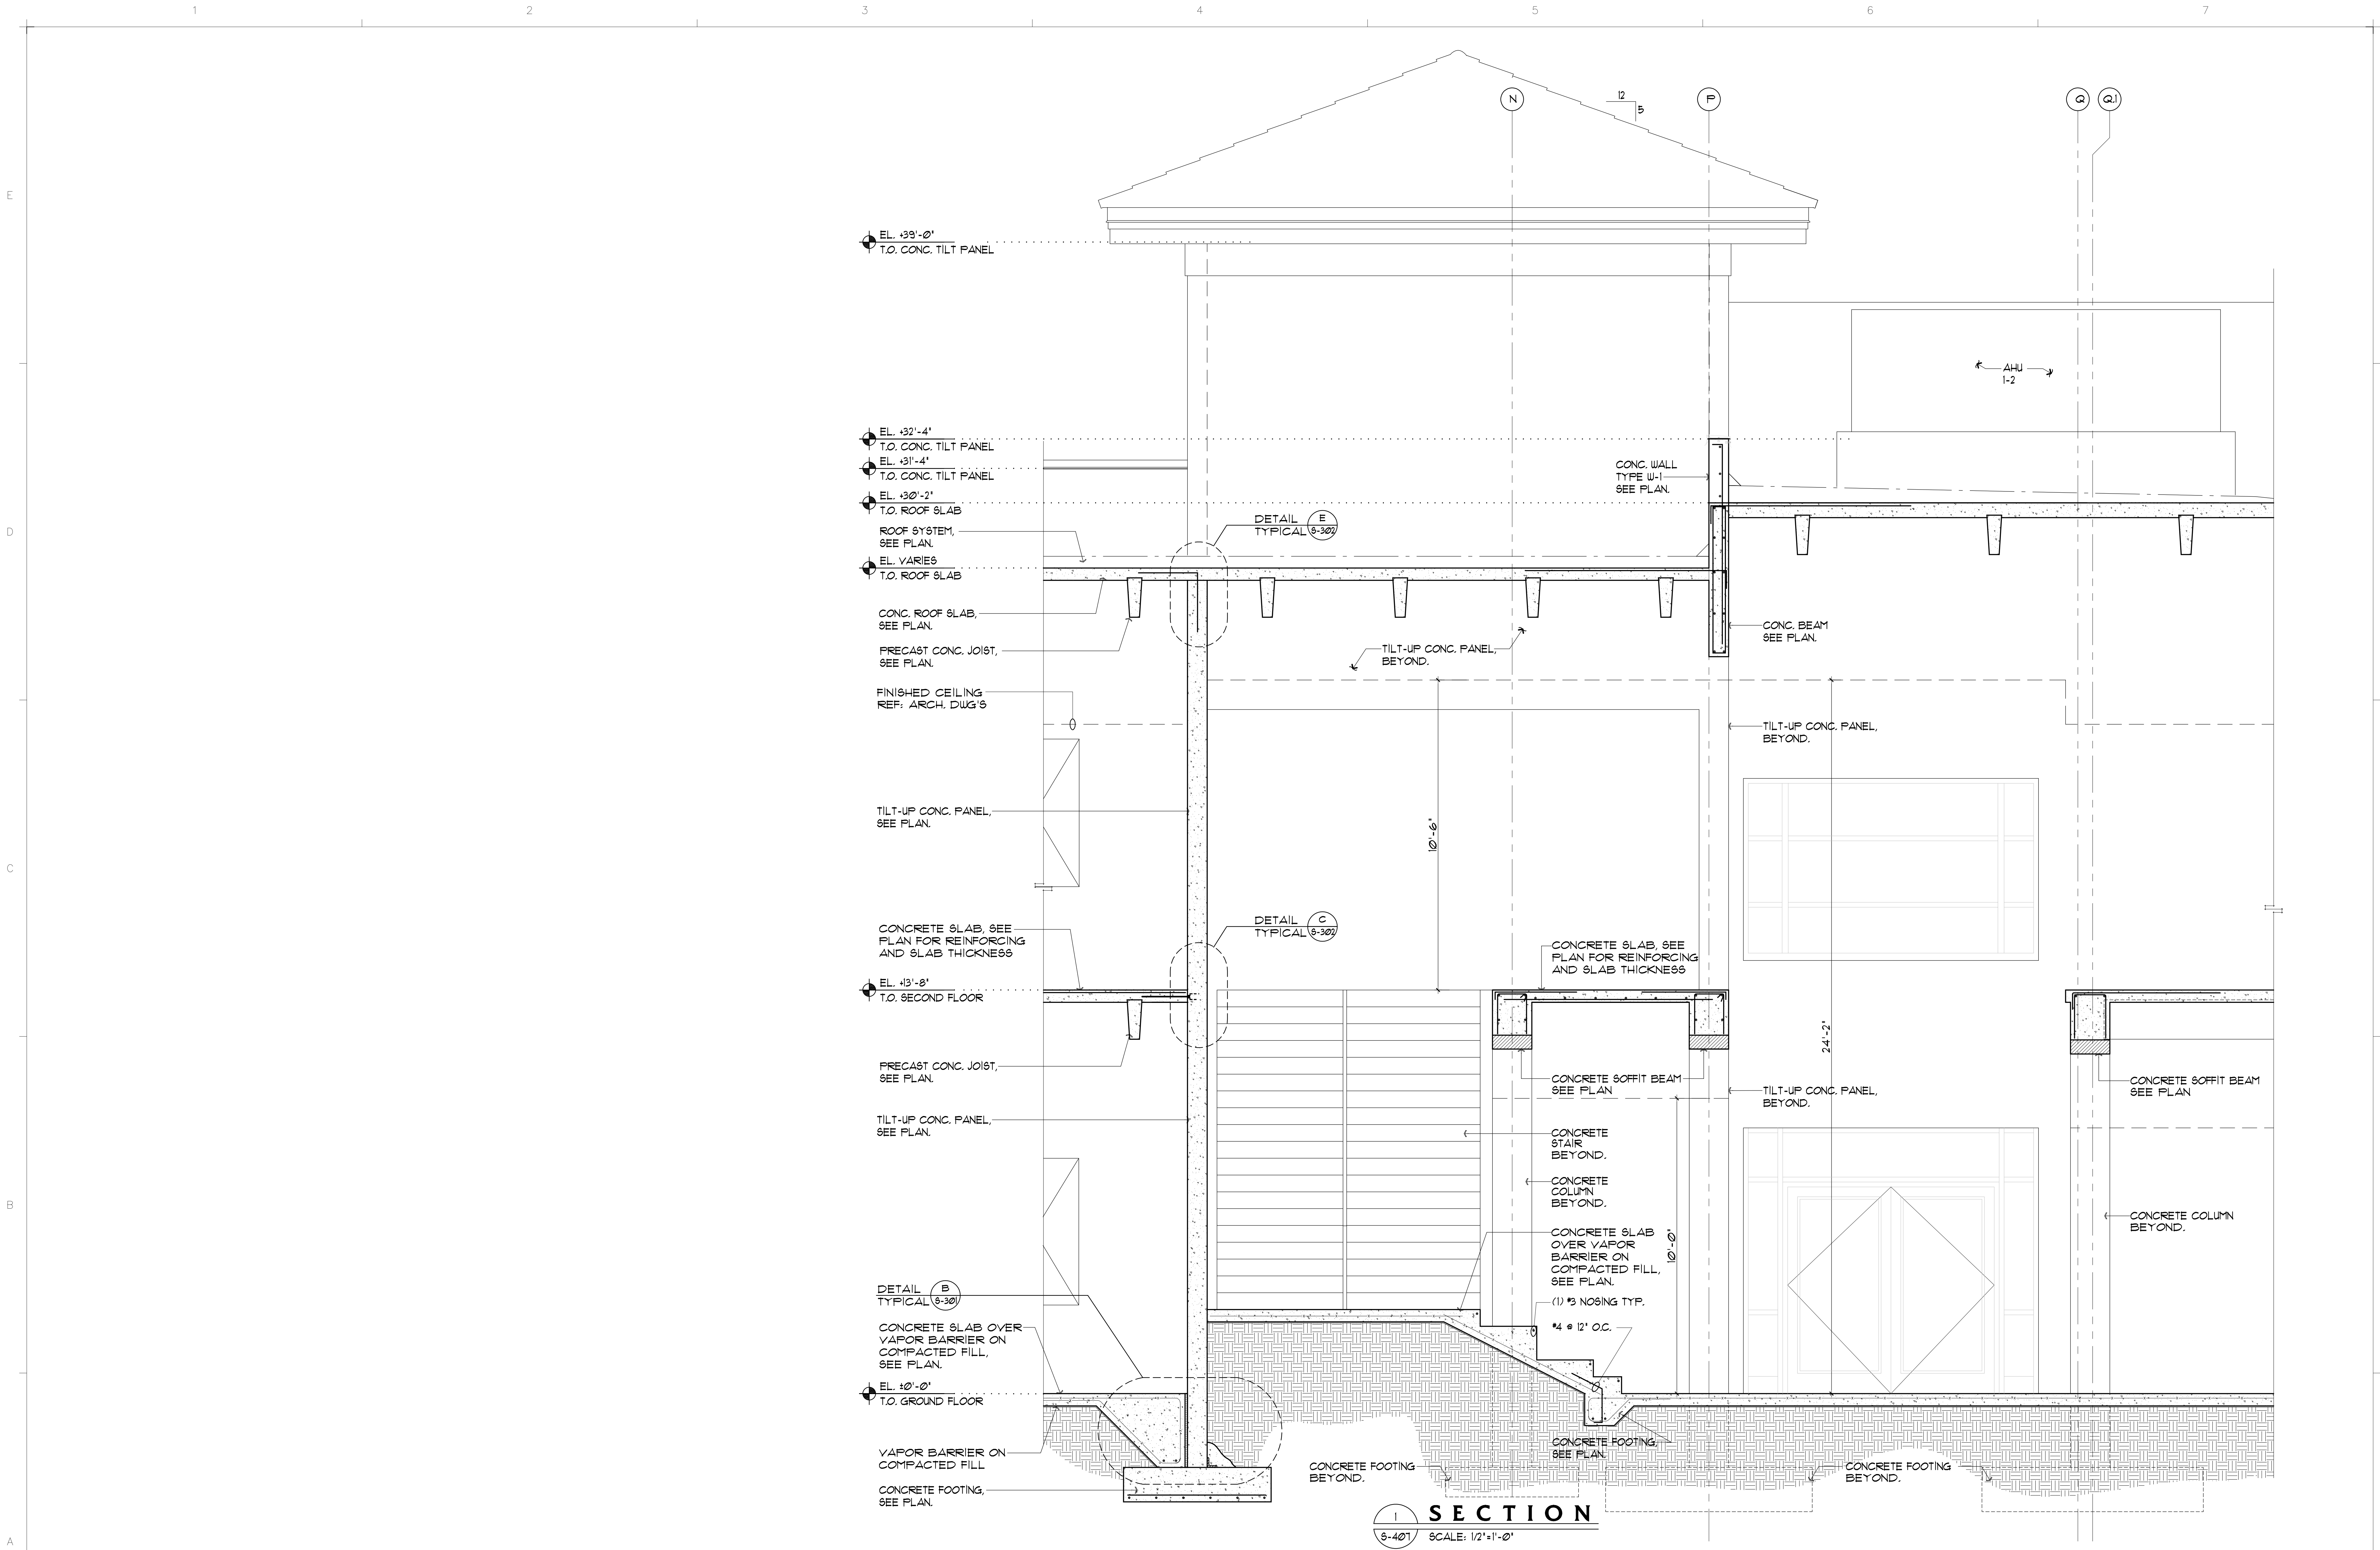

CHECKED BY: LR.	DRAWN BY: C.V.
--------------------	-------------------


CONSULTANT INFO:




D.D.A. ENGINEERS P.A. CONSULTING
4930 S.W. 74TH Court
Miami, Florida, 33155
Phone: (305)666-0711
Fax: (305)666-6269
www.ddaeng.com
2019-42-A



NEW ELEMENTARY SCHOOL (K-5)
VENETIAN PARC WEST
SOUTHWEST 157th AVENUE and 174th STREET
MIAMI, FL. 33187
MDCPS PROJECT No. 01892600

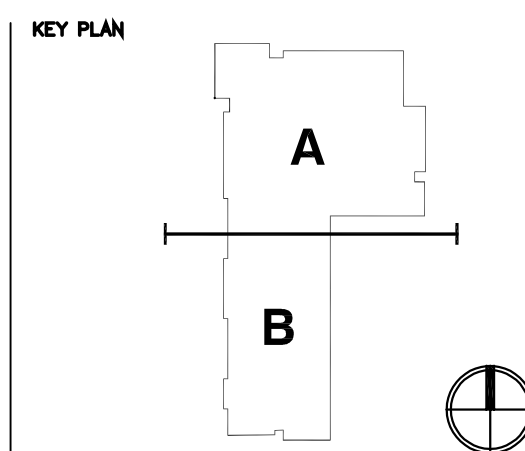


CONSULTANT INFO:

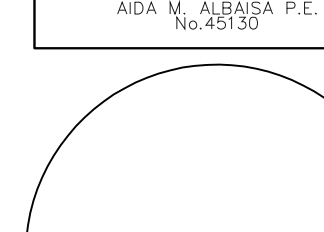

ADA M. ALBESA P.E.
No. 0150

RODRIGUEZ ARCHITECTS INCORPORATED
2121 PONCE DE LEON BLVD. STE 1010
CORAL GABLES, FL. 33134
TEL: (305) 448-3373
FAX: (305) 448-3374
A A C -- 0 0 1 9 3 3

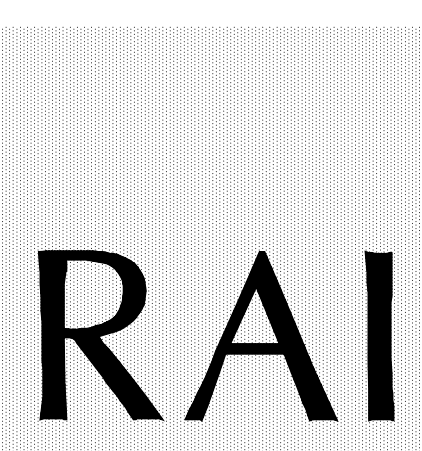

REVISIONS:

DRAWING TITLE: **SECTIONS**

SCALE: AS NOTED

ISSUE DATE: 10.11.19	PROJECT NO: 1906
-------------------------	---------------------

SHEET: **S-407**